

PROJECT GENERAL NOTES		
A.	IN ADDITION TO THE GENERAL NOTES LISTED HEREIN, THE LATEST EDITION OF AIA DOCUMENT A201 GENERAL CONDITIONS OF THE CONTRACT FOR CONSTRUCTION SHALL APPLY.	CC. GENERAL CONTRACTOR IS RESPONSIBLE TO CONTACT (client, landlord, etc) TO VERIFY, COORDINATE AND COMPLY DURING THE BIDDING PHASE, WITH REQUIREMENTS INCLUDING, BUT NOT LIMITED TO BARRICADES, STAGING, CONSTRUCTION PROCEDURES, USE OF MANDATED SUBCONTRACTORS, DEBRIS REMOVAL, RESTRICTED HOURS OF CONSTRUCTION, SECURITY, UTILITIES, ETC.
B.	WORK SHALL BE IN ACCORDANCE WITH FEDERAL, STATE AND LOCAL CODES, ORDINANCES, LAWS AND REQUIREMENTS.	DD. GENERAL CONTRACTOR SHALL FURNISH AND INSTALL ITEMS WHICH ARE OBVIOUS AND NECESSARY TO ENSURE QUALITY WORKMANSHIP AND INSTALLATION, EVEN IF NOT SPECIFICALLY MENTIONED IN THE DRAWINGS, INCLUDING BUT NOT LIMITED TO BLOCKING AND BRACING.
C.	WORK, WHEN COMPLETED, SHALL CONFORM TO THE AMERICANS WITH DISABILITIES ACT AND LOCAL ACCESSIBILITY REQUIREMENTS.	EE. ANY DEVIATION FROM THESE CONSTRUCTION DOCUMENTS ON THE PART OF THE GENERAL CONTRACTOR, ANY SUBCONTRACTOR, VENDOR AND/OR SUPPLIER, OR USE OF THESE CONSTRUCTION DOCUMENTS FOR USE AT ANY LOCATION OTHER THAN THAT FOR WHICH THEY WERE INTENDED, SHALL RELEASE WILKUS ARCHITECTS, AND ITS SUBSIDIARIES, AND THEIR OFFICERS, DIRECTORS, SHAREHOLDERS, AGENTS, EMPLOYEES, REPRESENTATIVES, SUCCESSORS AND ASSIGNEES, FROM ANY AND ALL LIABILITY INCURRED IN LITIGATION OR OTHERWISE WITH RESPECT TO THE CONSTRUCTION OF THIS PROJECT.
D.	THE CONSTRUCTION DOCUMENTS ARE COMPLEMENTARY, AND WHAT IS REQUIRED BY ONE SHALL BE AS BINDING AS IF REQUIRED BY ALL. COORDINATE PORTIONS OF WORK AS DESCRIBED IN THE CONSTRUCTION DOCUMENTS.	FF. GENERAL CONTRACTOR IS RESPONSIBLE FOR THE WORK AND THAT OF THE SUBCONTRACTORS FOR THE LOSSES AND DAMAGES TO EQUIPMENT, EXISTING CONSTRUCTION, TOOLS AND MATERIALS USED IN CONJUNCTION WITH THE WORK, FOR THE ACTS OF THEIR EMPLOYEES AND SUBCONTRACT WORKERS.
E.	THE CONSTRUCTION DOCUMENTS, AS DEFINED BY THE DRAWING AND SPECIFICATION INDEX, ARE NECESSARY TO DEFINE THE TOTAL PROJECT. PARTIAL PLANS OR SPECIFICATIONS SHOULD NOT BE ISSUED BY ANY PARTIES FOR BIDDING OR CONSTRUCTION.	GG. GENERAL CONTRACTOR SHALL ADHERE AND COMPLY WITH FEDERAL, STATE AND LOCAL REGULATIONS REGARDING JOB SAFETY.
F.	IT IS THE INTENT OF THE CONSTRUCTION DOCUMENTS TO DESCRIBE A COMPLETE AND FINISHED PROJECT, OTHER THAN ITEMS NOTED "NIC" (NOT IN CONTRACT), ERRORS, OMISSIONS AND INCONSISTENCIES THAT MAY OCCUR BETWEEN THE CONSTRUCTION DOCUMENTS AND/OR EXISTING CONDITIONS SHALL BE BROUGHT IMMEDIATELY TO THE ATTENTION OF THE ARCHITECT IN WRITING AND WITHOUT DELAY. THE ARCHITECT SHALL BE HELD RESPONSIBLE FOR THE RESULTS OF ANY ERRORS, DISCREPANCIES AND/OR OMISSIONS WHICH THE GENERAL CONTRACTOR FAILED TO NOTIFY THE ARCHITECT PRIOR TO CONSTRUCTION AND/OR FABRICATION OF THE WORK.	HH. GENERAL CONTRACTOR IS RESPONSIBLE TO CARRY WORKER'S COMPENSATION AS REQUIRED BY LAW AND/OR GOVERNING AUTHORITY.
G.	GENERAL CONTRACTOR SHALL INCLUDE AND PROVIDE ALL LABOR, MATERIALS, EQUIPMENT, TRANSPORTATION AND PAY EXPENSES INCURRED IN THE PROPER COMPLETION OF WORK UNLESS SPECIFICALLY NOTED TO BE THE WORK OF OTHERS. GENERAL CONTRACTOR SHALL PERFORM WORK NECESSARY FOR PRODUCTION OF A COMPLETE, HABITABLE PROJECT AS DEFINED BY THE SCOPE OF WORK.	II. GENERAL CONTRACTOR IS RESPONSIBLE FOR THE SAFETY AND CARE OF ADJACENT PROPERTIES DURING CONSTRUCTION.
H.	DO NOT SCALE DRAWINGS. BIDDER (CONTRACTOR) SHALL VERIFY CONDITIONS AND DIMENSIONS AT JOB SITE PRIOR TO START OF CONSTRUCTION. IF DISCREPANCIES ARE FOUND, WHETHER BLIND OR NOT, THE ARCHITECT SHALL BE NOTIFIED FOR CLARIFICATION BEFORE COMMENCING WORK. THE STATED DIMENSIONS SHALL TAKE PRECEDENCE OVER GRAPHIC. THE ARCHITECT SHALL BE NOTIFIED OF ANY DISCREPANCIES.	JJ. GENERAL CONTRACTOR IS RESPONSIBLE FOR MAINTAINING A COMPLETE AS-BUILT SET OF CONSTRUCTION DRAWINGS AT THE JOB SITE AND TURNING THE AS-BUILT DRAWINGS OVER TO THE CLIENT UPON COMPLETION OF THE PROJECT.
I.	NOTE THAT ERRORS IN THE TRANSMISSION OR REPRODUCTION OF THESE CONSTRUCTION DOCUMENTS COULD RESULT IN ALTERATIONS TO LINE TYPES, THICKNESSES, TEXT, COLORS, HATCH PATTERNS AND SCALE. WILKUS ARCHITECTS IS NOT RESPONSIBLE FOR ANY CLAIMS, DAMAGES OR EXPENSES ARISING FROM THE UNAUTHORIZED USE OF THE INFORMATION CONTAINED WITHIN.	KK. THE APPROVED PLANS (FOR CONSTRUCTION SET) SHALL BE KEPT ON SITE AT ALL TIMES, INCLUDING ALL ADDENDA, SUPPLEMENTAL INSTRUCTIONS, CHANGE ORDERS, COPIES OF APPROVED SUBMITTALS, ETC.
J.	IF THE CONSTRUCTION DOCUMENTS APPEAR TO BE UNCLEAR, AMBIGUOUS OR CONTRADICTORY, AND IN THE EVENT THAT THE CONTRACTOR, OR THE SUBCONTRACTOR, DETERMINES CLARIFICATION OR INTERPRETATION BY THE ARCHITECT IS REQUIRED, THE GENERAL CONTRACTOR SHALL SUBMIT A REQUEST FOR INFORMATION IN WRITING TO THE ARCHITECT PRIOR TO START OF THE WORK.	LL. IF REQUIRED, THE GENERAL CONTRACTOR SHALL PROVIDE SCHEDULING AND/OR COORDINATION WITH THE APPROPRIATE REPRESENTATIVE FOR THE FOLLOWING INSTALLATION PROCEDURES: a. INSTALLATION OF CONDUIT AND PIPING IN OR BELOW THE FLOOR SLAB b. CONNECTIONS TO DOMESTIC WATER, SANITARY AND GREASE WASTE, SANITARY VENT AND SMOKE/FIRE ALARMS. c. INSTALLATION OF PRIMARY DUCTWORK, VAV BOXES AND CONTROLS, PROGRAMMING AND TESTING OF THE VAV BOX CONTROL, AIR SENSORS. d. ANY WORK REQUIRED AT THE BUILDING SWITCHGEAR. e. HARDWARE AND SOFTWARE MODIFICATIONS TO COMPLETE THE INTERFACE WITH BASE BUILDING LIFE SAFETY SYSTEM. g. UPON SUBSTANTIAL COMPLETION OF WORK IN THE PREMISES, CLIENT AND THE CONTRACTOR SHALL CONDUCT A FINAL INSPECTION AND PREPARE A PUNCHLIST WHICH ENUMERATES ANY AREAS OF CONSTRUCTION, FIXTURING, LIGHTING OR LAMPING, MERCHANDISING, ETC., THAT ARE NOT IN ACCORDANCE WITH THE CONSTRUCTION DOCUMENTS. ANY STOREFRONT BARRICADE MAY NOT BE REMOVED UNTIL THE INSPECTION AND REQUIRED CORRECTIONS HAVE BEEN COMPLETED.
K.	IF THE CONSTRUCTION DOCUMENTS APPEAR TO BE UNCLEAR, AMBIGUOUS OR CONTRADICTORY, AND IN THE EVENT THAT THE CONTRACTOR, OR THE SUBCONTRACTOR, DETERMINES CLARIFICATION OR INTERPRETATION BY THE ARCHITECT IS REQUIRED, THE GENERAL CONTRACTOR SHALL SUBMIT A REQUEST FOR INFORMATION IN WRITING TO THE ARCHITECT PRIOR TO START OF THE WORK.	h. PROVIDE LANDLORD REQUIRED PROOF OF BUILDERS RISK INSURANCE AND DAMAGE DEPOSIT PRIOR TO BEGINNING OF ANY SELECTIVE DEMOLITION OR CONSTRUCTION PROCEDURES.
a.	REQUESTS FOR INFORMATION MAY ONLY BE MADE BY THE GENERAL CONTRACTOR. THE GENERAL CONTRACTOR SHALL CLEARLY AND CONCISELY SET FORTH THE ISSUE FOR WHICH CLARIFICATION IS SOUGHT AND WHY A RESPONSE IS NEEDED FROM THE ARCHITECT AND/OR CONSULTANTS. IN THE REQUEST FOR INFORMATION, THE CONTRACTOR SHALL SET FORTH AN ANTICIPATED RESPONSE TIME OF THE REQUIREMENT, ALONG WITH A REASON WHY SUCH AN UNDERSTANDING WAS REACHED.	MM. GENERAL CONTRACTOR TO VERIFY REQUIREMENTS TO MAINTAIN ROOF WARRANTY, ANY ROOF PATCHING SHALL RETURN THE AFFECTED AREA TO A "LIKE NEW" CONDITION.
b.	THE ARCHITECT WILL REVIEW THE REQUEST FOR INFORMATION TO DETERMINE IF IT IS WITHIN THE MEANING OF THIS TERM. IF THE ARCHITECT DETERMINES THAT IT IS NOT A REQUEST FOR INFORMATION, IT WILL BE RETURNED TO THE CONTRACTOR UNVIEWED AS TO CONTENT OR FOR RE-SUBMITTAL IN THE PROPER FORM AND MANNER.	NN. GENERAL CONTRACTOR ASSUMES COMPLETE RESPONSIBILITY WHEN CLIENT FURNISHED ITEMS ARE ACCEPTED AND RECEIVED BY THE GENERAL CONTRACTOR OR THEIR AGENTS.
c.	RESPONSES TO REQUESTS FOR INFORMATION SHALL BE ISSUED UPON RECEIPT, BUT NO LATER THAN FIVE WORKING DAYS OF RECEIPT. UNLESS IT IS DETERMINED THAT A LONGER PERIOD OF TIME IS NEEDED IN ORDER TO PROVIDE ADEQUATE RESPONSE. IF A LONGER PERIOD OF TIME IS NECESSARY, THE ARCHITECT WILL, WITHIN FIVE WORKING DAYS OF THE RECEIPT OF THE REQUEST FOR INFORMATION, NOTIFY THE GENERAL CONTRACTOR OF THE ANTICIPATED RESPONSE TIME.	OO. PROVIDE PROTECTION FOR EXISTING OR NEWLY INSTALLED SYSTEMS AND FINISHES FOR THE DURATION OF CONSTRUCTION.
d.	IF THE REQUEST FOR INFORMATION IS SUBMITTED WITH FIVE WORKING DAYS OR LESS FLOAT ON THE PROJECT SCHEDULE, THE CONTRACTOR SHALL NOT BE ENTITLED TO ANY TIME EXTENSION DUE TO THE TIME REQUIRED TO REVIEW AND RESPOND TO THE REQUEST FOR INFORMATION WITHIN THE FIVE WORKING DAYS AS SET FORTH ABOVE.	PP. GENERAL CONTRACTOR TO INSTALL DUST PROOFING AND/OR RIGID BARRIERS AS APPROPRIATE TO DEFINE VARIOUS SEGMENTS. BARRIERS TO MAINTAIN EXISTING, MECHANICAL, AND FIRE/LIFE SAFETY REQUIREMENTS FOR BUILDING OCCUPANTS.
e.	RESPONSES FROM THE ARCHITECT ARE NOT INTENDED TO CHANGE ANY OF THE REQUIREMENTS OF THE CONSTRUCTION DOCUMENTS. IN THE EVENT THAT THE CONTRACTOR BELIEVES A RESPONSE WILL CAUSE A CHANGE TO THE REQUIREMENTS OF THE CONSTRUCTION DOCUMENTS, THE CONTRACTOR SHALL IMMEDIATELY GIVE WRITTEN NOTICE TO THE ARCHITECT AND CLIENT STATING THAT THEY CONSIDER THE RESPONSE TO BE A CHANGE ORDER. FAILURE TO GIVE SUCH WRITTEN NOTICE IMMEDIATELY SHALL WAIVE THE CONTRACTORS RIGHT TO SEEK ADDITIONAL REPAIRS AND/OR COSTS.	QQ. GENERAL CONTRACTOR IS RESPONSIBLE FOR INSPECTION OF PORTIONS OF WORK ALREADY PERFORMED TO DETERMINE THAT SUCH PORTIONS ARE IN PROPER CONDITION TO RECEIVE SUBSEQUENT WORK.
L.	ANY DIMENSIONS, DETAILS, NOTES AND/OR SYMBOLS THAT APPLY TO ONE UNIT, APPLY TO ALL UNITS IN LIKE SITUATIONS, UNLESS NOTED OTHERWISE.	RR. MOLD AND MOISTURE MITIGATION - GENERAL CONTRACTOR TO COORDINATE AND ENSURE THAT ANY AREA OF THE BUILDING, MATERIAL, OR ASSEMBLY WITHIN THE BUILDING ENVELOPE IS THOROUGHLY CLEANED AND DRY BEFORE BEING COVERED BY CONSTRUCTION. ANY MOLD, MILDEW OR OTHER MOISTURE CONDITION DEVELOPED WITHIN THE SCOPE OF WORK OF THIS CONTRACT (DEMOLITION OR NEW CONSTRUCTION) SHALL BE CORRECTED AND/OR MITIGATED BY THE GENERAL CONTRACTOR PRIOR TO ADDITIONAL WORK. CONTACT BETWEEN DISSIMILAR METALS SHALL BE LIMITED. WHEN REQUIRED, THE CONTACT SHALL BE PROTECTED AS REQUIRED.
M.	FOR THE PURPOSE OF THESE DOCUMENTS, "INSTALL" SHALL MEAN TO PROVIDE FASTENERS, MISCELLANEOUS HARDWARE, BLOCKING, ELECTRICAL CONNECTIONS, PULPING CONNECTIONS AND/OR HARDWARE REQUIRED FOR A COMPLETE AND OPERATIONAL INSTALLATION, UNLESS NOTED OTHERWISE.	SS. ALL SHUTOFFS OF MECHANICAL, PLUMBING, ELECTRICAL, FIRE ALARM AND/OR FIRE SPRINKLER SYSTEMS SHALL BE COORDINATED WITH THE LANDLORD AND COMPLY WITH THE AUTHORITY HAVING JURISDICTION'S REQUIREMENTS FOR NOTIFICATION, FIRE WATCH, RE-TESTING, ETC. REMOVE COMBUSTIBLE RUBBISH DURING CONSTRUCTION FROM THE PROJECT LIMITS CONTINUOUSLY AND DISPOSE OF IN A LEGAL MANNER.
N.	FOR THE PURPOSE OF THESE DOCUMENTS, "BY GC" WILL REFER TO ITEMS PROVIDED AND INSTALLED BY THE GENERAL CONTRACTOR, THE SUBCONTRACTORS AND/OR AGENTS. THE TERM "BY CLIENT" WILL REFER TO ITEMS PROVIDED BY THE CLIENT AND INSTALLED BY THE GENERAL CONTRACTOR.	UU. VENDORS ARE RESPONSIBLE FOR DISPOSAL OF SHIPPING/CRATING MATERIALS. VERIFY WITH THE GENERAL CONTRACTOR THE USE OF THE DUMPSITE ON SITE. SUBCONTRACTORS MUST DISPOSE OF THEIR CONSTRUCTION DEBRIS. IF NOT COMPLETED, IT WILL BE COMPLETED AND BACK CHARGED FOR CLEANING. COORDINATE DISPOSAL WITH JOB SUPERINTENDENT.
O.	PRODUCTS THAT HAVE BEEN USED IN PREPARING THESE DOCUMENTS, ARE TO ESTABLISH MINIMUM QUALITIES. PROPOSED SUBSTITUTIONS MUST MEET THESE QUALITIES, OR BETTER, TO BE CONSIDERED ACCEPTABLE. THE BURDEN OF PROOF OF EQUALITY RESTS WITH THE GENERAL CONTRACTOR. ADEQUATE SUPPORTING DOCUMENTATION MUST ACCOMPANY SUBSTITUTION REQUEST SUBMITTALS, WHICH MUST BE SUBMITTED TO THE ARCHITECT FOR APPROVAL PRIOR TO BIDDING.	VV. AT THE TIME OF PROJECT COMPLETION, THE PROJECT LIMITS ARE TO BE THOROUGHLY CLEANED PRIOR TO TURNOVER TO CLIENT.
P.	GENERAL CONTRACTOR SHALL VISIT THE PROJECT SITE PRIOR TO SUBMISSION OF BID AND BEGINNING OF ANY WORK TO EXAMINE AND COMPARE THE DRAWINGS AND SPECIFICATIONS TO THE EXISTING CONDITIONS AND BE KNOWLEDGEABLE OF WORK TO BE PERFORMED. NOTIFY ARCHITECT IMMEDIATELY OF ANY DISCREPANCIES.	
Q.	NOTIFY ALL PARTIES IF HAZARDOUS MATERIALS ARE SUSPECTED OR FOUND TO BE PRESENT.	
R.	NOTIFY ARCHITECT IMMEDIATELY OF EXISTING CONDITIONS THAT ARE EXPOSED DURING CONSTRUCTION THAT MAY IMPACT ANY PROPOSED NEW WORK.	
S.	DO NOT ATTEMPT REMOVAL OF ANY STRUCTURE OR ELEMENT SUSPECTED OF BEING STRUCTURAL IN NATURE. STRUCTURAL MODIFICATIONS TO THE BUILDING OR STRUCTURAL SYSTEMS (OF ANY TYPE) REQUIRE APPROVAL FROM THE BUILDING OWNER AND AN APPROVED STRUCTURAL ENGINEER.	
T.	GENERAL CONTRACTOR TO PROVIDE TEMPORARY BARRICADES, WINDOW BLACKOUTS AND DUST CONTROL AS REQUIRED BY CLIENT, LANDLORD OR AUTHORITY HAVING JURISDICTION FOR THE DURATION OF CONSTRUCTION.	
U.	VEHICULAR ACCESS MUST BE PROVIDED AND MAINTAINED SEVICEABLE THROUGHOUT CONSTRUCTION.	
V.	THROUGHOUT THE PROJECT, THE GENERAL CONTRACTOR SHALL CLOSELY SUPERVISE THE WORK OF SUBCONTRACTORS AND SHALL BE SOLELY RESPONSIBLE FOR CONSTRUCTION MEANS, METHODS AND TECHNIQUES, INCLUDING SAFETY PROCEDURES AND FOR COORDINATING/SEQUENCING WORK.	
W.	GENERAL CONTRACTOR SHALL TAKE OUT ANY NECESSARY TRADE-LEVEL PERMITS, INSURANCE, LICENSES, BONDS AND CERTIFICATES AND PAY ALL FEES CONNECTED TO THE WORK DESCRIBED HEREIN.	
X.	ALL CONTRACTORS FOR THE WORK ARE REQUIRED TO HAVE INSURANCE OF ALL TYPES AND LIMITS, AS REQUIRED FOR THIS PROJECT.	
Y.	REFER TO ENGINEERED CONSTRUCTION DOCUMENTS BY OTHERS FOR ADDITIONAL PERTINENT INFORMATION.	
Z.	ABBREVIATIONS ARE PER THE UNITED STATES NATIONAL CAD STANDARD - FOUND IN MODULE 5 - TERMS AND ABBREVIATIONS.	
AA.	REFER TO INDIVIDUAL DRAWINGS WITHIN THIS SET OF CONSTRUCTION DOCUMENTS FOR ADDITIONAL GENERAL NOTES.	



STORE NO.: 4757



CLIENT:



CHIPOTLE MEXICAN GRILL, INC.
PO BOX 182966
COLUMBUS, OH 43218-2966
TELEPHONE: (614) 318-2682
INTERNET: WWW.CHIPOTLE.COM

COPYRIGHT 2024
THIS DRAWING IS AN INSTRUMENT OF SERVICE AND
AS SUCH REMAINS THE PROPERTY OF CHIPOTLE
MEXICAN GRILL, INC. PERMISSION FOR USE OF THIS
DOCUMENT IS LIMITED AND CAN BE EXTENDED ONLY
BY WRITTEN AGREEMENT WITH CHIPOTLE MEXICAN
GRILL, INC.

PROJECT INFORMATION:

STORE NO.: 4757
"ANDERSON IN"
S SCATTERFIELD RD & 59TH STREET
ANDERSON, IN 46013

SEAL:



July 25, 2024

MATTHEW M. WILKUS
LICENSE #AR11700110
(EXPIRES 12/31/2024)

PROJECT NO. 2022-0494

DRAWN BY RDB

CHECKED BY

ISSUE RECORD:

12/12/2023	PERMIT SET
06/19/2024	BID SET
07/24/2024	CONSTRUCTION SET

REVISIONS:

TITLE:

PROJECT DATA &
LIFE SAFETY PLAN

SHEET NUMBER:

G001

LIFE SAFETY GENERAL NOTES

- A. LIFE SAFETY SYSTEMS SHALL BE DESIGNED PER APPLICABLE FIRE PREVENTION CODE, ORDINANCE OR LAW.
- B. POST "NO PARKING - FIRE LANE" SIGNS ALONG APPROVED VEHICULAR ACCESS ROADS. COORDINATE LOCATIONS WITH LOCAL AUTHORITY HAVING JURISDICTION.
- C. AN ALL WEATHER FIRE ACCESS ROAD SHALL BE IN PLACE BEFORE ANY COMBUSTIBLE MATERIALS ARE PLACED ON SITE. COORDINATE WITH LOCAL AUTHORITY HAVING JURISDICTION.
- D. FIRE APPARATUS ACCESS ROADS SHALL BE UNOBSTRUCTED. ACCESS GATES SHALL BE APPROVED PRIOR TO INSTALLATION AND SHALL BE IN COMPLIANCE WITH O.S.H.A. GUIDELINES.
- E. COMMERCIAL DUMPSTERS OR CONTAINERS WITH A CAPACITY OF ONE AND A HALF CUBIC YARDS OR GREATER SHALL NOT BE STORED OR PLACED WITHIN FIVE FEET OF COMBUSTIBLE WALLS OR OPENINGS, UNLESS THESE ARE PROTECTED BY AN APPROVED AUTOMATIC FIRE SPRINKLER SYSTEM.
- F. BUILDING ADDRESS NUMBERS SHALL BE PROVIDED AT THE FRONT OF THE TENANT SPACE AND SHALL BE VISIBLE AND LEGIBLE FROM THE PUBLIC RIGHT-OF-WAY AND A MINIMUM OF 6" HIGH. NUMBERS SHALL CONTRAST WITH THEIR BACKGROUND. ADDRESS NUMBERS SHALL BE PROVIDED AND INSTALLED BY THE GENERAL CONTRACTOR.
- G. THE SUITE ADDRESS SHALL BE POSTED ON THE BUILDING WHERE IT IS CLEARLY VISIBLE FROM THE FIRE LANE. THE SUITE ADDRESS MUST BE POSTED IN NUMBERS THAT ARE A MINIMUM OF 4" TALL AND ON THE SERVICE DOOR IN NUMBERS A MINIMUM OF 4" TALL.
- H. THE ADDRESS SHALL BE PERMANENTLY POSTED ON UTILITY SERVICE DISCONNECTS IN NUMBERS A MINIMUM OF 1" TALL AND ON THE SERVICE DOOR IN NUMBERS A MINIMUM OF 4" TALL.
- I. A KNOX BOX IS TO BE PROVIDED AND INSTALLED BY THE GENERAL CONTRACTOR. VERIFY WITH THE LOCAL AUTHORITY THIS REQUIREMENT AND COORDINATE LOCATION AS REQUIRED.
- J. COMPLETE PLANS AND SPECIFICATIONS FOR THE FIRE ALARM SYSTEMS: FIRE-EXTINGUISHING SYSTEMS, INCLUDING AUTOMATIC SPRINKLERS AND WET AND DRY STANDPIPES; HALON SYSTEMS AND OTHER SPECIAL TYPES OF AUTOMATIC FIRE-EXTINGUISHING SYSTEMS AND OTHER FIRE PROTECTION SYSTEMS AND APPURTENANCES SHALL BE SUBMITTED TO AUTHORITIES HAVING JURISDICTION FOR REVIEW AND APPROVAL PRIOR TO INSTALLATION. ENGINEERED AUTOMATIC FIRE ALARM AND DETECTION SYSTEM PLANS, CALCULATIONS AND SPECIFICATIONS SHALL BE DESIGNED BY AN APPROVED INSTALLER AND SUBMITTED TO THE LOCAL AUTHORITY HAVING JURISDICTION PRIOR TO ANY WORK BEING COMPLETED TO THE SYSTEM.
- L. THE CENTER OF FIRE ALARM INITIATING DEVICES (BOXES) SHALL BE LOCATED ABOVE THE LEVEL OF THE FLOOR, WORKING PLATFORM, GROUND SURFACE OR SIDEWALK AS REQUIRED TO MEET APPLICABLE CODES, ORDINANCES AND LAWS.
- M. THE INSTALLATION AND MODIFICATION OF THE FIRE SUPPRESSION SYSTEM, INCLUDING ANSUL SYSTEMS, SHALL COMPLY WITH THE BUILDING CODE AND N.F.P.A. MODIFICATIONS TO THE FIRE SUPPRESSION SYSTEM WILL BE PROVIDED, PERMITTED, INSTALLED AND INSPECTED UNDER A SEPARATE DEFERRED PERMIT APPLICATION.
- N. FIRE ALARM SYSTEMS SHALL BE DESIGNATED AS CLASS "A" SYSTEMS.
- O. GENERAL CONTRACTOR SHALL CONTACT THE LANDLORD DURING THE BIDDING PHASE OF THE PROJECT FOR ANY REQUIREMENTS FOR THE FIRE ALARM SYSTEMS. THESE SYSTEMS, IF REQUIRED, SHALL BE INCLUDED IN THE BID AND CONSTRUCTION FOR THIS PROJECT.
- P. REQUIRED EGRESS DOORS SHALL BE OPENABLE FROM THE INSIDE WITHOUT THE USE OF A KEY OR ANY SPECIAL KNOWLEDGE OR EFFORT AND SHALL SWING IN THE DIRECTION OF EGRESS TRAVEL. SPECIAL LOCKING DEVICES SHALL BE OF AN APPROVED TYPE.
- Q. EXITS SHALL BE ILLUMINATED AT ANY TIME THE BUILDING IS OCCUPIED WITH LIGHTS HAVING AN INTENSITY OF NOT LESS THAN 11.0 LUX AT FLOOR LEVEL, OR AS DIRECTED BY LOCAL CODE.
- R. EXIT SIGNS TO BE PROVIDED AND INSTALLED AS REQUIRED BY APPLICABLE CODES, ORDINANCES AND LAWS.
- S. PROVIDE APPROVED EXITING ILLUMINATION AND ILLUMINATED EXIT SIGNS WHICH ARE POWERED FROM SEPARATE CIRCUITS AND COMPLY WITH THE BUILDING CODE.
- T. ANY RATED WALL ASSEMBLIES AND/OR FLOOR/CEILING ASSEMBLIES LOCATED IN AN ATTIC SPACE OR IN A CONCEALED SPACE SHALL BE IDENTIFIED WITH PERMANENT SIGNAGE OR STENCILING. SUCH IDENTIFICATION SHALL BE LOCATED WITHIN 15'-0" OF THE END OF THE WALL AND AT INTERVALS NOT EXCEEDING 30'-0". LETTERING MUST BE NOT LESS THAN 3" IN HEIGHT WITH A MINIMUM 3/8" STROKE. IN CONTRASTING COLOR. INDICATE THE TYPE AND RATING OF THE CONSTRUCTION OR AS REQUIRED BY LOCAL CODE.
- U. OCCUPANT LOAD SIGN WITH MINIMUM 1" LETTERS AND NUMBERS SHALL BE POSTED NEAR MAIN EXIT.
- V. FIRE DAMPERS SHALL BE PROVIDED WHERE AIR DUCTS PENETRATE ANY FIRE RATED ASSEMBLIES.
- W. EXIT LIGHTING AND SIGNS SHALL HAVE 6" HIGH LETTERING IN ACCORDANCE WITH LOCAL CODES. PROVIDE LOW LEVEL EXIT SIGNS PER CODE REQUIREMENTS.
- X. FIRE DEPARTMENT FINAL INSPECTION REQUIRED.
- Y. EXITS, EXIT SIGNS, FIRE ALARM PANELS, HOSE CABINETS, FIRE EXTINGUISHER LOCATIONS, AND STANDPIPE CONNECTIONS SHALL NOT BE CONCEALED BY CURTAINS, MIRRORS, OR OTHER DECORATIVE MATERIAL.
- Z. FIRE EXTINGUISHER NOTES
- a. PROVIDE AND INSTALL FIRE EXTINGUISHERS AS DIRECTED BY AUTHORITY HAVING JURISDICTION. EXTINGUISHERS IN BACK OF HOUSE AREAS MAY BE IN BRACKETS. PUBLIC AREAS ARE TO BE ENCLOSED IN RECESSED CABINETS, PAINTED TO MATCH ADJACENT WALL FINISH. PROVIDE "K" TYPE FIRE EXTINGUISHER IN KITCHEN AREAS, WITHIN 30'-0" OF TRAVEL FROM ANY POINT WITHIN THE KITCHEN OR FOOD PREPARATION AREAS. VERIFY INSTALLATION LOCATIONS WITH LOCAL FIRE MARSHAL PRIOR TO INSTALLATION.
- c. 5 LB. "ABC" FIRE EXTINGUISHERS ARE REQUIRED WITHIN 75'-0" OF TRAVEL FROM ANY POINT IN PUBLIC AREAS. THEY MUST BE MOUNTED CONSPICUOUSLY, PREFERABLE ALONG NORMAL TRAVEL PATHS AND EXIT WAYS. VERIFY INSTALLATION LOCATIONS WITH LOCAL FIRE MARSHAL PRIOR TO INSTALLATION.

CODE ANALYSIS

CODE AUTHORITIES

BUILDING CODE:	2014 INTERNATIONAL BUILDING CODE
MECHANICAL CODE:	2014 INTERNATIONAL MECHANICAL CODE
PLUMBING CODE:	2014 INTERNATIONAL PLUMBING CODE
ENERGY CODE:	2014 INTERNATIONAL ENERGY CONSERVATION CODE
FUEL GAS CODE:	2014 INTERNATIONAL FUEL GAS CODE
ELECTRICAL CODE:	2009 NATIONAL ELECTRICAL CODE
FIRE CODE:	2014 INTERNATIONAL FIRE CODE
FOOD CODE:	INDIANA FOOD CODE 410 IAC 7-24
ACCESSIBILITY CODE(S):	2009 ANSI ICC A117.7

CHAPTER 3: OCCUPANCY CLASSIFICATION AND USE

TENANT OCCUPANCY GROUP: A-2

CHAPTER 5: GENERAL BUILDING HEIGHTS AND AREAS

TENANT USE GROUP: A-2, ASSEMBLY - RESTAURANT

ALLOWABLE BUILDING AREA:	6,000 SF	(PER SHELL DRAWINGS)
ACTUAL BUILDING AREA:	2,325 SF	(PER SHELL DRAWINGS)

ALLOWABLE NO. OF STORIES:	1	(PER SHELL DRAWINGS)
ACTUAL NO. OF STORIES:	1	(PER SHELL DRAWINGS)
ALLOWABLE BUILDING HEIGHT:	40' - 0"	(PER SHELL DRAWINGS)
ACTUAL BUILDING HEIGHT:	20' - 9"	(PER SHELL DRAWINGS)

CHAPTER 6: TYPES OF CONSTRUCTION

CONSTRUCTION TYPE: V-B (PER SHELL DRAWINGS)

FIRE-RESISTANCE RATING REQUIREMENTS:

PRIMARY STRUCTURAL FRAME	0 HOUR
EXTERIOR BEARING WALL	0 HOUR
INTERIOR BEARING WALLS	0 HOUR
INTERIOR NON-BEARING WALLS & PARTITIONS	0 HOUR
EXTERIOR NON-BEARING WALLS & PARTITIONS	0 HOUR
FLOOR CONSTRUCTION	0 HOUR
ROOF CONSTRUCTION	0 HOUR

CHAPTER 8: INTERIOR FINISHES

INTERIOR WALL AND CEILING FINISH REQUIREMENTS:

TYPE OF SPACE	FINISH CLASS
INTERIOR EXIT STAIRWAYS AND RAMPS AND EXIT PASSAGEWAYS	A
COORDINORS AND ENCLOSURE FOR EXIT ACCESS STAIRS	A
ROOMS AND ENCLOSURED SPACES	B

CHAPTER 9: FIRE PROTECTION AND LIFE SAFETY SYSTEMS

AUTOMATIC SPRINKLER SYSTEM:	NO	(PER SHELL DRAWINGS)
FIRE ALARM SYSTEM:	NO	(PER SHELL DRAWINGS)

CHAPTER 10: MEANS OF EGRESS

DESIGN OCCUPANT LOAD:

Function of Space	Occupant Load Factor	Plan Measurement	Occupant Load
Assembly Area without Fixed Seating (Standing Space)	5 SF / Occ. (Net)	95 SF	19
Assembly Area with Fixed Seating	1 Seat / Occ.	37 Seats	37
Assembly Area with Fixed Seating (Booths)	24" Booth L. / Occ.	188"	8
Kitchens, Commercial Area	200 SF / Occ. (Gross)	1,157 SF	6
Business Area	100 SF / Occ. (Gross)	51 SF	1
Total:			71 Occ.

POSTED OCCUPANT LOAD 71 + 20 PATIO SEATS = 91 OCC.

RESTAURANT SEATING COUNT

INTERIOR SEATS:	37 Seats
EXTERIOR PATIO SEATS:	20 Seats
TOTAL SEAT COUNT:	57 Seats

MEANS OF EGRESS REQUIRED: 2
MEANS OF EGRESS PROVIDED: 3

EXIT CONFIGURATION
DIAGONAL DIMENSION OF AREA SERVED: 73' - 3"
REQUIRED EXIT SEPARATION DISTANCE: 30' - 8"
PROVIDED EXIT SEPARATION DISTANCE: 46' - 6 1/2"

EXIT ACCESS TRAVEL DISTANCE

MAXIMUM ALLOWED: 200' - 0"
MAXIMUM PROVIDED: 56' - 11"

COMMON PATH OF EGRESS TRAVEL DISTANCE

MAXIMUM ALLOWED: 75' - 0"
MAXIMUM PROVIDED: 18' - 9"

CHAPTER 29: PLUMBING SYSTEMS

MINIMUM NUMBER OF REQUIRED PLUMBING FIXTURES

	WATER CLOSETS		LAVATORIES		URINALS	
	REQ'D	PROV'D	REQ'D	PROV'D	REQ'D	PROV'D
MALE:	1	1	1	1	0	0
FEMALE:	1	1	1	1	0	0


ABBREVIATIONS

(E) EXISTING CONSTRUCTION	EL ELEVATION (VERTICAL HEIGHT)	HES TENANT'S HVAC EQUIPMENT SUPPLIER	MSS MUSIC SYSTEMS SUPPLIER	SPS SODA POP SUPPLIER	THS TENANT'S HARDWARE SUPPLIER	TSS TENANT'S SMART SAFE SUPPLIER
(N) NEW CONSTRUCTION	ELEC ELECTRICAL	HS HOOD SUPPLIER	NIC NOT IN CONTRACT	SS SUPPORT SIGNAGE	TLS TENANT'S LIGHT/LAMP SUPPLIER	TSV TENANT'S SIGN VENDOR
@ AT	ELEV ELEVATION	HVAC HEATING AND VENTILATING	NO NUMBER	T TENANT	TMB TENANT'S MENU BOARD SUPPLIER	TUV TENANT'S UV SUPPLIER
AFF ABOVE FINISH FLOOR	EQ EQUAL	ICP INITIAL COST PROJECTION	OC ON CENTER	TAB TENANT'S TEST & BALLANCE VENDOR	TMS TENANT'S MILLWORK SUPPLIER	TYP TYPICAL
ARCH ARCHITECT(URAL)	EXT EXTERIOR	INT INTERIOR	OSB ORIENTED STRAND BOARD	TBD TO BE DETERMINED, SEE FIELD REFERENCE MANUAL	TPS TENANT'S PHONE SUPPLIER	UNO UNLESS NOTED OTHERWISE
ASS ALARM SYSTEM SUPPLIER	FC FOR CONSTRUCTION	KES KITCHEN EQUIPMENT SUPPLIER	PDC PROTECT DURING CONSTRUCTION	TCC TENANT'S CABLING CONTRACTOR	TRS TENANT'S RAILING SUPPLIER	UPS UNINTERRUPTED POWER SUPPLY
BD BOARD	FRP FIBERGLASS REINFORCED PANEL	MAX MAXIMUM	POS POINT OF SALE	TEMS TENANT'S ENERGY MANAGEMENT SYSTEM SUPPLIER	TP TENANT'S PANELBOARD SUPPLIER	VIF VERIFY IN FIELD
BLDG BUILDING	GRT FIRE RETARDANT-TREATED	MECH MECHANICAL	PREP PREPARATION		TPS TENANT'S PANELBOARD SUPPLIER	WCS TENANT'S WALK-IN COOLER SUPPLIER
CMU CONCRETE MASONRY UNIT	GA GAUGE	MFR MANUFACTURER	QT QUARRY TILE		TRS TENANT'S RAILING SUPPLIER	WHS WATER HEATER SUPPLIER
CO2 CO2 SUPPLIER	GALV GALVANIZED	MIN MINIMUM	R RADIUS		TS TENANT'S SAFE SUPPLIER	Ø DIAMETER OR ROUND
CO2AS CO2 ALARM SUPPLIER	GC GENERAL CONTRACTOR	MISC MISCELLANEOUS	RTU ROOF TOP UNITS			
DIM DIMENSION(S)						
EA EACH						

LIFE SAFETY LEGEND

0' - 0" - (0' - 0")	EXIT ACCESS TRAVEL DISTANCE (COMMON PATH IF APPLIES)		ASSEMBLY AREA WITHOUT FIXED SEATS (STANDING SPACE)
	PROPOSED FIRE EXTINGUISHER LOCATION - GENERAL CONTRACTOR TO VERIFY THE EXACT TYPE, LOCATION(S) AND QUANTITIES WITH THE AUTHORITIES HAVING JURISDICTION PRIOR TO ORDERING AND INSTALLING FIRE EXTINGUISHERS		ASSEMBLY AREA WITH FIXED SEATS
	WALL MOUNTED EXIT SIGN		ASSEMBLY AREA WITH FIXED SEATS (BOOTHS)
EGRESS AT DOORS			KITCHENS, COMMERCIAL AREA
	EGRESS BREAKDOWN: OCCUPANTS SERVED EXIT WIDTH REQUIRED EXIT WIDTH PROVIDED		BUSINESS AREA
			UNOCCUPIED AREAS (RESTROOMS, UNOCCUPIABLE SPACES, MEANS OF EGRESS)

2.1 Materials: A. Resinous Flooring: Manufacturer: aiflooring - Contact: 1218 West 41st Street, Suite B, Tulsa, Oklahoma 74107. Phone: 918-445-0627 2.1 Flooring System: A. System Description: Clear, thin film system 18-22 mils thick with texture agent added for slip resistance. - TerraPrime: A 2 component, 100% solids clear polyamide-cured epoxy coating. - TerraThane Satin: A 2 component, 90% solids polyurea clear finish coat. - TerraGrip: A graded, plastic aggregate added to finish coat for slip resistance. 2.3 Product Substitutions: A. Substitutions: No substitutions permitted. 2.4 Source Quality: A. Source Quality: Obtain resinous materials, including patching and leveling materials from a single manufacturer. 3.1 Manufacturer's Instructions: A. Compliance: Comply with manufacturer's product data, including product technical data sheets and application instructions. 3.2 Examination: A. Site Verifications of Conditions: Verify substrate conditions, which have been previously installed under other sections, are acceptable for product installation in accordance with manufacturer's instructions. - Before applying materials, inspect surfaces to receive new materials and report any unsatisfactory conditions. Absence of any such report shall constitute installer's acceptance of surfaces as satisfactory for installing materials. 3.3 Preparation: A. Adjacent Surfaces Protection: Protect adjacent work areas and finish surfaces from damage during product installation. B. Surface Preparation: - Mechanical Cleaning: Concrete floor surfaces receiving polymer flooring systems shall be thoroughly cleaned and prepared by shotblasting and/or diamond grinding. - Patching Damaged Substrate: Holes, voids, static cracks, and other substrate surface defects should be patched and repaired according to manufacturer's recommendations. - Prepare and clean control joints well and fill with an appropriate elastomeric. 3.4 Installation: A. Resinous Flooring Installation: The following are abbreviated guidelines that should provide for basic application steps for the installation of the systems. Detailed instructions should be obtained from the manufacturer. - Patching: After substrate preparation, surface defects shall be patched according to manufacturer's recommendations. - Priming: Apply aiflooring TerraPrime, 100% solids epoxy primer, at a rate of 125-150 square feet per gallon. Allow 6-12 hours (depending on temperatures) of cure before applying finish coat. Finish coat must be applied within 24 hours of TerraPrime application. - Finish Coat: Apply aiflooring TerraThane Satin, 90% solids polyurea topcoat, at a rate of 200 square feet per gallon. TerraGrip should be added to the TerraThane mix at a rate of 1 pint per 3 gallon kit for slip resistance. Note that TerraThane Satin must be metered out by notched squeegee prior to rolling. B. Cleaning: Remove temporary coverings and protection of adjacent work areas. Repair or replace damaged installed products. Clean installed products in accordance with manufacturer's instructions prior to Owner's acceptance. Remove construction debris from project site and legally dispose of debris. 3.5 Protection: A. Protection: Protect installed product and finish surfaces from damage during construction.	3.1 Installation A. Surface Conditions - Examine substrate, with installer present, for conditions affecting performance of finish. Correct conditions detrimental to timely and proper work. Do not proceed until unsatisfactory conditions are corrected. - Verify that base slab meets finish and surface profile requirements in Division 3 Section "Cast-In-Place Concrete," and Project Conditions above. - Prior to application, verify that floor surfaces are free of construction latents. B. Application The following RetroPlate process will be followed as listed below: A concrete grinding machine must be used. Please proceed accordingly. The process is as follows: - Floors should be started using 50, 80 or 100 grit diamond pucks depending on the condition of the slab. - Clean the floor using automatic scrubber or comparable. - Grind floor using 200 grit resin diamonds. - Clean the floor using automatic scrubber or comparable. - Apply RetroPlate 99 to floor at 200 sq. ft. per gallon, scrubbing product into the floor and allowing product to soak until turning slick. If it becomes sticky, apply water to the surface as necessary, leaving the product on the floor for at least 60 minutes. - Grind floor using 400 grit resin diamonds. - Clean the floor using automatic scrubber or comparable. - Clean and remove any excess RetroPlate. Let the floor dry overnight. - Continue the polishing process using 800 grit resin diamonds. - Clean the floor using automatic scrubber or comparable. - Alternately, depending on slab condition, grind floor using 1200-1500 grit resin diamonds. - Clean the floor using automatic scrubber or comparable. - The same process will be used for new floors as well as rehab floors. Floor prep for the rehab floors will be separate. - Apply an even coat of RetroGuard Sealer with a brush, roller, or low-pressure sprayer, and when surface is dry, burnish the floor with a black burnishing pad. Apply a second coat of RetroGuard one hour after the initial application, and again burnish the floor with a black burnishing pad. - Do not walk on surface for 12 hours, and do not introduce any water or moisture for at least 48 hours, allowing for proper drying and setting of RetroPlate and RetroGuard. Water will minimize the sealing properties of RetroPlate and RetroGuard. C. Start any of the floor finish applications in presence of manufacturer's technical representative. D. Sealing, Hardening and Polishing of Concrete Surface - Concrete must be in place a minimum of 28 days or as directed by the manufacturer before application can begin. - Application is to take place at least 10 days to the prior to racking and other in-store accessory installation, thus providing a complete, uninhibited concrete slab for application. - Only a certified applicator shall apply RetroPlate 99. Procedures must be followed as recommended by the product manufacturer and as required to match approved test sample. - Achieve waterproofing, hardening, dust-proofing, and abrasion resistance of the surface without changing the natural appearance of the concrete, except for the sheen. - Polish to a level 2 shine. E. Workmanship and Cleaning - The premises shall be kept clean and free of debris at all times. - Remove spatter from adjoining surfaces, as necessary. - Repair damages to surface caused by cleaning operations. - Remove debris from jobsite - Dispose of materials in separate, closed containers in accordance with local regulations.	H. Accessories - Reinforcing bars: ASTM A615, Grade 60, deformed billet steel bars of sizes indicated. - Wall weeps: Dur-O-Wal D/A 1006 "Cell Vent", clear flexible polypropylene co-polymer. - Compressible joint material: Dur-O-Wal "Rapid Soft-Joint" D/A 2010. - Bond breaker strips: ASTM D226 No. 15 asphalt saturated roofing felt. - Cleaning agents: - Face Brick and CMU: ProSoCo, Inc., "Sure Klean New Masonry Cleaners." - ACMU: ProSoCo, Inc., "Sure Klean Burnished Custom Masonry Cleaner." - Expansion/Control joint sealants: Polyurethane-based, elastomeric joint sealant complying with ASTM C920 and Section 07900 requirements. Color matched to adjacent surfaces. 3.1 Installation A. Preparation - Wet absorbent face brick masonry units requiring wetting, in accordance with BIA recommendations. - Lay concrete masonry units dry. - Establish, lines, levels and coursing. Ensure ties, anchors and flashing are correctly installed - Mix mortar cementitious materials and aggregate in a mechanical mixer. Add water in amount to provide satisfactory workable consistency of mortar. Retemper mortar as required within two hours of mixing to replace water lost be evaporation. Discard mortar after two and one-half hours of initial mixing. Do not use mortar after it has started to set. B. Installation - General: - Build walls and other masonry construction to the full thickness shown. Build single wythe walls to the actual thickness of the masonry units, using units of nominal thickness shown. - Cut masonry units using motor-driven masonry saws to provide clean, sharp edges. Cut units to fit adjoining work neatly. Provide 100% solid units where cores would be exposed. - Cold weather construction, hot weather construction, and masonry construction tolerances: Comply with unit masonry standard ACI 530.1/ASCE 6/TMS 602 requirements. C. Laying Masonry - Layout walls in advance to ensure accurate spacing of surface bond patterns, with uniform joint widths, and to properly locate openings, movement type joints, returns and offsets. Do not use less than half-size units at corners, jamps and other locations. - Lay up walls plumb and true to comply with ACI 530.1 tolerances. Provide square corners and angles, except as otherwise indicated, with courses level, accurately spaced and coordinated with other work. - Pattern bond: Running bond. Do not use units with less than 4" of horizontal face dimensions at corners or jamps. - Lay hollow CMU/ACMU with full mortar coverage on horizontal and vertical face shells. Bed CMU webs in mortar in starting courses. Maintain uniform 3/8" joint widths. - Lay face brick and solid CMU/ACMU with completely filled bed and head joints. Do not slush head joints. Maintain uniform 3/8" joint widths. - Compress and cut joints flush for masonry walls below grade or covered by other materials. - Tool joints in all exposed masonry work to a concave joint. - Provide interlocking masonry bond in each course at corners and intersecting walls. - As the work progresses, build in masonry accessories and related items. Fill in solidly with masonry around built-in items. - Bed hollow metal frame anchors in mortar and fill space between hollow metal frames and masonry solid with fine mortar grout. - Provide solid masonry bearing for all lintels, beams, joists, plates and load-bearing members. - Take particular care to embed all conduits and pipes within concrete masonry without fracturing exposed shells and to fit units around switch, receptacle and other boxes set in walls. Where electric conduit, outlets, switch boxes and similar items occur, grind and cut units before building in services. - Install anchors, plates and related work built into masonry work. - Install reinforcing steel and concrete fill where indicated. Comply with drawing details. - Horizontal joint reinforcing: Provide continuous joint reinforcing at all concrete masonry walls as follows: - In every second block course, 16" on center vertically, full height of wall and every block course where shown on the drawings. - Lap reinforcement a full width at the corners and at intersections or use special fabricated sections. - Fully embed side rods in mortar. - Anchoring masonry work: Provide anchoring devices of the type indicated or required. - Provide vertical expansion, control and isolation joints in masonry where indicated. - When not indicated, at maximum 30'-0" on center. - Locate control joints at points of natural weakness in masonry and acceptable to Architect. - Joint sealant color shall match masonry materials sealed. - Lintels: Install loose steel lintels furnished under structural steel work where shown. Set lintels in full bed of mortar. - Flashing and weeps: - Install concealed through wall masonry flashing at all wall sills, masonry openings in exterior walls with masonry above head, over all horizontal steel members built into masonry and elsewhere as indicated. Provide "drainage wall system" masonry construction. - Provide end dams and positive slope to drain. Extend flashing vertically at least 8" and built into or anchor to back-up with a termination bar for a complete watertight installation. - Flexible Membrane Flashing: - Install membrane flashing in accordance with manufacturer's installation instructions. - Fully adhere flashing to substrate. - Lap flashing joints a minimum of 6", seal and roll with a hand roller. - Trim bottom edge 1/4" back from exposed face of masonry. - Seal edges, seams, cuts and penetrations with manufacturer's recommended mastic. - Install weeps in head joints of final course of exterior masonry wythe above flashing. Space weeps maximum of 24" on center horizontally and located to avoid door openings. Install weeps at head joints with outside face of weep material held 1/8" from the finish face of masonry unit. - Install compressible joint material at lintels and horizontal steel members. Build in joint fillers and seal with elastomeric joint sealant. D. Masonry Veneer Walls: - Metal framed walls: Tie exterior masonry veneer wythe to back-up wall with individual metal ties screwed to metal stud framing. - Space ties 16" on center vertically and horizontally. - Maintain veneer wall cavity free of mortar droppings during masonry installation. E. Parging: - Dampen masonry walls prior to parging. - Scarify each parging coat to ensure full bond to subsequent coat. - Parge masonry walls in two uniform coats of mortar to a total thickness of 3/4 inch (19mm). - Steel trowel surface smooth abs flat with a maximum surface variation of 1/8 inch per foot (1mm/meter). F. Architectural Concrete Masonry Units: Install ACMU in accordance with the manufacturer's installation instructions and the following: - Draw ACMU from more than one pallet at a time during installation. G. Reinforced Concrete Masonry - Reinforce and fill CMU/ACMU wall and column masonry where indicated. Fill all cores solid with concrete fill. Comply with NCMA TEK Bulletins 3-2, 3-A and 14-2 recommendations. - Comply with drawing details for reinforcing steel size and spacing. - Install bond beams where indicated. Reinforce and fill units solid with concrete fill. Comply with drawing details for reinforcing steel size and spacing. H. Repair, Pointing and Cleaning - In process cleaning: Wipe off excess mortar as the work progresses. Dry brush with bristle brushes exposed masonry at the end of each day's work. Remove mortar spatters and joint ridges. - Clean all exposed masonry. Cleaning agents subject to Architect's approval. Before applying any cleaning agent to the entire wall, clean a sample wall area of approximately 20 square feet in a location acceptable to the Architect. Do not proceed with final cleaning until the sample area has been allowed to dry a minimum of 3 days and the test area cleaning approved. Protect all windows, doors, louvers, metal lintels and other corrodible parts. Damaged materials and work replaced at Contractor's expense. - Dry clean exposed surfaces to remove large particles of mortar using hardwood wood paddles and scrapers. Metal tools not acceptable. - Presoak exposed masonry surfaces by saturating with water and flush off loose mortar and
--	--	---

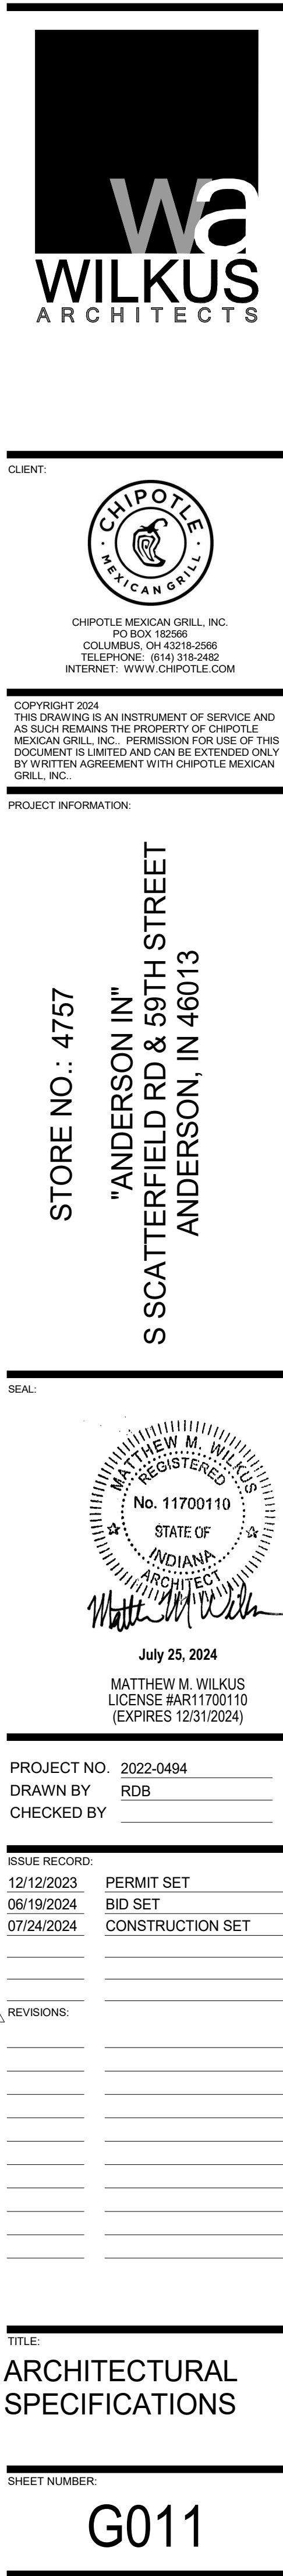

SECTION 07512 - ROOFING SYSTEM REPAIR

1.1 General: When penetration of the existing roofing system is required to accommodate new construction, perform necessary roofing system repair.

- A. Coordination: Before starting work, verify with the Tenant's Construction Manager and the Owner the following:
- Existing roof system materials and installation methods.
 - Repair work responsibilities and warranty requirements. To maintain original warranty, where provided use original roof contractor.
- B. Qualifications: Repair work shall be performed only by an experienced roofing installer approved or licensed by the existing roofing system materials manufacturer; with not less than five years of successful experience installing and repairing roofing systems similar to this projects existing roofing system.

2.1 Materials:

- A. Provide and install only materials approved and recommended by the roofing manufacturer for repairing the existing roofing system.

3.1 Installation:

- A. Preparation: Inspect roof surface conditions with roof manufacturer's representative to verify extent and location of any other repairs required to ensure a watertight roofing system upon completion of the repair work.
- B. Make necessary repairs. Match existing roof slope, insulation materials and roofing membrane materials, except as otherwise approved by the existing roofing system manufacturer to accommodate new construction and repair work.
- C. Install curb flashing furnished by mechanical and electrical trades for new roof top equipment.

SECTION 07540 - THERMOPLASTIC MEMBRANE (PVC) ROOFING

1.1 General: Provide the thermoplastic membrane (PVC) roofing system as shown and specified.

- A. Standards: Materials and construction shall conform to following:
- ASTM D5036 "Application of Adhered Poly(Vinyl Chloride) Sheet Roofing."
 - FM 1-29 Loss Prevention Data Adhered or Mechanically Attached Single Ply Membrane Roof Systems."
 - NRCA "Single-Ply Roofing Membrane."
 - UL "790 - Tests for Fire Resistance of Roof Covering Materials."

- B. Installer Qualifications: An experienced roofing installer approved by roofing system manufacturer and with not less than five years of successful experience installing membrane roofing systems similar to those required for this project.

- C. Deliver, store and handle roof system materials in accordance with manufacturer's recommendations to avoid damage and deterioration.
- Comply with manufacturer's recommendations for handling and protection during installation.

- D. Install roofing work only when weather conditions are in compliance with manufacturer's specific environmental requirements and conditions will permit work to be performed in accordance with manufacturer's recommendations and warranty requirements.
- Protect adjacent materials and surfaces from damage and soiling during roofing system installation.
 - Provide special protection on completed roofing work.
 - Protect paving and structure walls adjacent to hoists before starting work.
 - Do not overload the building structure with storage of materials or installation equipment on the substrate decking.

E. Warranty

- Contractor and roof system installer shall jointly warrant roofing materials and installation for a period of two years from the date of Substantial Completion. Warranty shall include roofing membrane, flashing, roof insulation, roofing accessories and sheet metal work provided under Section 07600.
- Manufacturer's warranty: Submit executed copy of roofing system manufacturer's 15 year total system warranty, including labor and materials for the entire roof system. Including perimeter edge metal, Section 07600 Flashing & Sheet Metal

2.1 Materials

- A. Manufacturer: Duro-Last Roofing, Inc. (800)248-0280, Austin Russell, austin.russell@holicim.com, www.duro-last.com
- Basic of Design Product Roofing System
 - Thermoplastic single ply membrane roofing system: DL Membrane (PVC) fully adhered, smooth surface, UL Class A fire-rated single ply membrane roofing system.
 - Thermoplastic fiber reinforced PVC membrane, not less than 40 mils (.040), complying with ASTM D4434 and membrane manufacturer's published physical properties.

- B. Comparable Alternate Roof Manufacturers:
- Versico Roofing Systems, (480) 528-6923, Jeff Kelly, jeff.kelly@versico.com
 - VersiFlex PVC Adhered System
 - Other comparable alternates can be considered when approved by Arch PM and Chipotle DM/CM.

- C. The roof covering design must resist a wind load of 100 mph, Exposure C and shall resist impact damage based on results of tests based on the results of tests conducted in accordance with ASTM D 3746, ASTM D 4272, CGSB 37-GP-52M or FM 4470
- Insulation cover board: Georgia-Pacific Corp. (800) 284-5347, internet www.gp.com, "Dens-Deck" nonstructural fiberglass-faced, silicone-treated gypsum core panels, 1/2" thickness.
 - Roof insulation: Rigid closed cell polyisocyanurate boards approved by the membrane manufacturer; complying with ASTM C1289, Type II, minimum 20 psi compressive strength, aged R-value equal 5.6 per inch of thickness.
 - Provide a double layer installation. Minimum total R-value as indicated on plans.
 - Specified perimeter edge metal shall be compliant with International Building Code ANSI / SPRI ES-1, ER2 testing requirements.
 - Flashing: Roof system manufacturer's standard sheet flashing of same material, type, and color as sheet membrane. Specified perimeter edge metal will be compliant with International Building Code ANSI / SPRI ES-1, RE2 testing requirements.
 - Membrane Bonding Adhesive: Roof system manufacturer's standard membrane bonding adhesive.
 - Insulation and Cover Board Adhesive: Dow Chemical Company, (888) 868-1183, internet www.flexibeproduts.com, "INSTA-STIK Professional Roof Insulation Adhesive", a single component, moisture cured polyurethane adhesive.
 - Fasteners: Roof system manufacturer's standard fasteners for project conditions indicated.
 - Accessories: Roof system manufacturer's recommended pourable sealers, preformed penetration flashing, preformed corner flashing, seam caulk, termination bars and other accessories required for substrate surfaces and installation conditions indicated.
 - Traffic walkways: Duro-Last Roof Track II walkway pads 3.1 Installation

3.1 Installation

- A. Preparation:
- Clean substrate surfaces of debris and other substances detrimental to roofing installation.
 - Correct unsatisfactory conditions before starting roofing. Roof deck surface conditions shall comply with manufacturer's requirements and be acceptable to the roofing system installer.
- B. Installation:
- General: Provide roofing system materials and installation complying with roofing system manufacturer's instructions and governing codes and regulations.
 - Mix and apply roof insulation and cover board adhesive in strict accordance with the adhesive manufacturer's installation instructions. Dispense adhesive at manufacturer's recommended application rate using approved dispensing equipment.
 - Roof insulation
 - Extend insulation full thickness over entire surface to be insulated. Cut and fit around obstructions; fill all voids with insulation. Provide saddles and tapered ends as required to provide positive proper drainage.
 - Install and secure in place with insulation adhesive, a double layer of insulation units of the required thickness. Run long joints of insulation in continuous straight lines, perpendicular to roof slope, with end joints staggered between rows. Stagger joints of each layer of insulation. Butt edges to moderate contact. Limit joints between adjacent units to maximum 1/4".
 - Insulation cover board: Install and secure in place with insulation adhesive a single layer of insulation cover board on installed roof insulation. Secure cover board in accordance with membrane manufacturer's recommendations. Stagger joints with joints of roof insulation.

- Thermoplastic membrane: Comply with membrane manufacturer's instructions and recommendations for handling and installing single ply membrane roofing.
 - Unroll and position roofing sheet membrane without stretching. Align top sheet with pr-marked lines on bottom sheet. Allow membrane to "relax" for at least 30 minutes before adhering, splicing and flashing.
 - Adhere membrane to insulation cover board with bonding adhesive. Broom bonded membrane to achieve maximum contact.
 - Join membrane seams using approved heat welding equipment. Check all splices for voids and repair voids with heat gun and roller.
 - When required, mechanically fasten membrane at roof perimeter, curb flashing and similar penetrations in accordance with manufacturer's installation instructions.
 - Flash and make weathertight all equipment curbs, pipes, conduits, drains and other penetrations or projections through sheet roofing using roofing system manufacturer's recommended flashing materials, accessories and procedures.
- Install roof accessories and traffic walkways in accordance with manufacturer's instructions.
- Install sheet metal work furnished under section 07600.

SECTION 07600 - FLASHING AND SHEET METAL

General:

- A. Standards: Materials and construction shall conform to following:
- SMACNA "Architectural sheet Metal Manual- 1993."
 - Installation: Performed under Section 07540 work.

1.1 Pre-manufactured perimeter edge metal and accessories

- Manufacturer: Duro-Last Roofing / Exceptional Metals, Inc. (800) 248-0280, Jason Dark, www.Duro-Last.com
- Duro-Last / Exceptional Metals Snap Coping made of 24-gauge galvalume, cover provided with Kynar architectural finish providing a 35 year finish warranty. Meets ANSI/SPRI ES-1 2003 method RE-2 testing requirements. (Color - Refer to Exterior Elevations)
 - Duro-Last / Exceptional Metals Vinyl backed scupper. Scupper profile & size indicated Fig 1-20.

1.2 General: Miscellaneous sheet metal

- A. Standards: Materials and construction shall conform to following:
- SMACNA "Architectural sheet Metal Manual- 1993."
 - Installation: Performed under Section 07540 work.

2.1 Materials:

- A. Galvanized steel: ASTM A653 commercial quality sheet steel with 0.2% copper, G90 hot-dip galvanized. Gage indicated.
- Scuppers: Minimum 16 gage.
 - Coping/Wall caps: Minimum 18 gage.
- B. Aluminum sheet: ASTM B209 alloy 3003, temper as required for forming and performance. Thickness indicated.
- Conductor Boxes: Minimum 0.040" thickness.
 - Downspouts: Minimum 0.025" thickness.
- C. Joint sealers: One-component silicone elastomeric joint sealant complying with ASTM C920. Color matched to sheet metal finish.
- D. Metal accessories: Provide sheet metal fasteners, clips, straps, anchoring devices and similar accessory units as required for installation of work, matching or compatible with material installed, non-corrosive, size and gage as required for performance and acceptable to the Architect.
- E. Fabrication: Shop fabricate sheet metal work to comply with profiles and sizes indicated and to comply with standard industry standards as shown by SMACNA in the "Architectural Sheet Metal Manual."
- Conductor boxes: SMACNA Chapter 1 - Roof Drainage Systems. Profile and size indicated Fig 1-25.
 - Scuppers: SMACNA Chapter 1 - Roof Drainage Systems. Profile and size indicated Fig 1-20.
 - Downspouts: SMACNA Chapter 1 - Roof Drainage Systems. Profile and size indicated. Installation Fig. 1-31 with strap hanger Fig. 1-35.
 - Formed coping/wall caps: SMACNA Chapter 3 - Copings. Design Fig 3-1. Profile and size indicated with Fig. 3-3 butt joints and concealed back-up plates. Install formed copings with continuous cleat fasteners similar to Fig 3-1 at exposed face and screw fasteners with washers space maximum 24" on center at roof side.

3.1 Installation:

- A. Preparation: Coordinate sheet metal work with other work for the correct sequencing of items which make up the entire roof system of weatherproofing and rain drainage:
- B. Installation: Comply with SMACNA "Architectural Sheet Metal Manual" recommendations, drawing details and approved shop drawings for installation of the work.
- Anchor sheet metal items securely in place by methods indicated, providing for thermal expansion. Conceal fasteners and expansion provisions whenever possible. Install joint sealants where required.
 - Set units true to lines and levels indicated. Install work with sealed laps, joints and seams that will be permanently watertight and weatherproof. Bed flanges of sheet metal work in thick coat of roofing cement or sealant compatible with roofing membrane.
 - Separate sheet metal work from dissimilar metals and treated wood materials. Provide rosin-sized paper slip sheet over treated wood.
 - Fabricate, support and anchor conductor boxes and downspouts to withstand thermal expansion, stresses and full loading by ice or water without damage, deterioration or leakage.

SECTION 076113 - SHEET METAL WALL PANELS

1.1 General:

- A. Standards:
- Furnish all labor, material, tools, equipment and services for all preformed fascia and wall panels as indicated, in accord with provisions of Contract Documents.
 - Completely coordinate work with work of all other trades.
 - Although such work is not specifically indicated, furnish and install all supplementary or miscellaneous items, appurtenances and devices incidental to or necessary for a sound, secure and complete installation.

B. Related work specified elsewhere:

- Structural steel: Section 05100
- Steel joists: Section 05200 or 05400
- Flashing and sheet metal: Section 07600

1.2 Quality Assurance:

- A. Applicable standards:
- SMACNA "Architectural Sheet Metal Manual" Sheet Metal and Air Conditioning Contractors National Association, Inc.
 - AISC: "Steel Construction Manual" American Institute of Steel Construction.
 - AISI: "Cold Form Steel Design Manual: American Iron and Steel Institute.
 - ASTM A792-83-AZ50: Specifications for steel sheet, aluminum-zinc alloy coated (galvanized) by the hot dip process, general requirements (Galvalume).
- B. Manufacturer's qualifications:
- Manufacturer has a minimum of three years experience in manufacturing metal wall systems of this nature. Panels specified in this section shall be produced in a factory environment (not job site roll formed) with fixed base roll forming equipment assuring the highest level of quality control. A letter from the manufacturer certifying compliance will accompany the product material submittals.

1.3 Product Delivery, Storage and Handling

- A. Delivery: Deliver metal wall system to job site properly packaged to provide protection against transportation damage.
- B. Handling: Exercise extreme care in unloading, storing and erecting metal wall system to prevent bending, warping, twisting and surface damage.
- C. Storage: Store all materials and accessories above ground on well skidded platforms. Store under waterproof covering. Provide proper ventilation of metal wall system to prevent condensation build up between each panel or trim/ flashing component.

2.1 Materials

- A. Metal wall system profile:
- Shadow Rib: 3 inch deep x 16 inch width with 1 1/2 inch deep x 5 1/4 inch wide fluting
- B. Metal wall system style:
- Fluted face
 - Concealed fasteners
- C. Gauge: 24 gauge
- D. Substrate: Per Plans
- E. Texture: Smooth
- F. Finish: Premium thermostet silicone polyester (20 year warranty)
- G. Color: Polar White, to be painted per Exterior Elevations
- H. Acceptable Manufacturer: MBCI Houston, Texas (281) 445-8555.

3.1 Surface Conditions

A. Examination:

- Inspect installed work of other trades and verify that such work is complete to a point where this work may continue.
- Verify that installation may be made in accordance with approved shop drawings and manufacturer's instructions.

3.2 Installation

- A. Install metal wall system system so that it is weathertight, without waves, warps, buckles, fastening stresses or distortion.
- B. Install metal wall system in accordance with manufacturer's instructions and shop drawings.
- C. Provide concealed anchors at all panel attachment locations.
- D. Install panels plumb, level and straight with seams parallel, conforming to design as indicated.

3.3 Cleaning, Protection

- A. Dispose of excess materials and remove debris from site.
- B. Clean work in accordance with manufacturer's recommendations.
- C. Protect work against damage until final acceptance. Replace or repair to the satisfaction of the architect and work that becomes damaged prior to final acceptance.
- D. Touch up minor scratches and abrasions.

3.4 Field Painting

- A. Refer to section 09900 on G017
- B. Follow manufacturer's technical bulletin for Precoated Signature 200 MBCI wall panels.

Section 07900 – JOINT SEALERS

1.1 General: Provide joint sealers as shown and specified.

- A. Standards: Comply with ASTM C 920 requirements.

- B. Application: Performed by skilled, experienced joint sealer applicators.

2.1 Materials:

- A. Poly urethane sealants:
- Tremco Commercial Sealants (800) 321-7906, internet www.tremcosealants.com,
 - "Dymonic FC" One component, fast skinning, Low Modulus Polyurethane.
 - "Dymeric 240 FC" Multi Component, gun grade, chemically curing, tintable fast setting polyurethane sealant.
 - Sonneborn, (724) 756-9582, internet www.sonneborn.com
 - Color pack for polyurethane multi component, gun grade chemically curing sealant.
- B. Silicone Sealants:
- General Electric Silicons, (800) 295-2392, internet www.gesilicones.com
 - "SCS1700 Sanitary – Mold/Mildew Resistant Silicone", one component 100% silicone, fungicidal based sealant.
 - "SCS2700 Silpruf Silicone" one component medium modulus, natural cure silicone all purpose sealant.
 - "Silglaze II SCS2800- Glazing Sealant" one component, 100% silicone based sealer.
 - "GE Paintable Silicone" one component paintable silicone.
 - "SCS1009 Silicone Sealant" one-component acetoxly silicone for general purpose sealing and bonding
 - Dow Corning Silicons, (989)496-4000, www.dowcorning.com
 - "Dow 795" – one component, medium modulus, natural cure silicone.
- C. Firestoping Sealants: 3M Fire Protection Products, (800) 328-1687, internet www.3M.com/firestop
- "3M Fire Barrier CP 25WB+ Caulk" or approved equal
- D. Joint backing: Non-absorptive, non-staining compressible, non-gassing, polyethylene foam backer rod compatible with joint sealants.

3.1 Installation:

- A. Preparation: Clean and prepare joints prior to installing sealers:
- Wipe shipping oils from surfaces to be sealed. Remove protective films and/or install joint backer rod if joint is larger than 1/2" in width.
- B. Installation: Install joint sealant materials in strict accordance with manufacturer's installation instructions.
- Apply sealants in a uniform, continuous bead without gaps or air pockets. Hand tool and finish all joints so that a smooth, small, lip free uniform line is created along the substrate being shot. Remove any excess materials from tooled edges and ends of joint.
 - Install joint sealants to a depth no more than 1/2 the width of the joint.
 - Install sealants by proven techniques that result in sealants directly contacting and fully wetting joint substrates, completely filling recesses provided for each joint configuration, and providing uniform, cross-sectional shapes and depths relative to joint widths which allow optimum sealant movement capability.
 - Immediately, after sealant application, and prior to time skinning or curing begins, tool sealants to form smooth, uniform beads of configuration indicated to eliminate air pockets, and to ensure contact and adhesion of sealant with sides of joint. Remove excess sealants from surfaces adjacent to joint. Do not use tooling agents which discolor sealants or adjacent surfaces or are not approved by sealant manufacturer.
 - Clean off excess sealants or sealant smears adjacent to joints as work progresses by methods and with cleaning materials approved by manufacturers of joint sealers and of products in which joints occur.

4.1 Sealant Schedule:

- A. Kitchen Area:
- Provide a continuous bead of white GE SCS1700 silicone at the following locations:
 - Ceiling grid to FRP wall panels
 - Base of FRP wall panels to T.O. specified base material.
 - Walk in cooler walls to FRP wall panels.
 - Stainless closure pieces at cooler walls to FRP wall panels.
 - FRP/stainless corner guards to FRP wall panels.
 - Ceiling tile pipe penetrations.
 - Wall pipe penetrations and/or escutcheons perimeters. (water & gas lines).
 - Mop sink stainless surround perimeter to walls.
 - FRP closure panel, at top of cooler, to cooler walls.
 - FRP wall panels to hollow metal door frames.
 - Coke line bundle to PVC cap.
 - FRP inside corner pieces to FRP wall panels. Both sides of corner piece.
 - Battery backup cover panel to FRP.
 - Faucet's to FRP wall panels.
 - FRP wall panels to quarry tile cove base.
 - FRP to aluminum plate at walk thru.
 - Menu board light bracket to ceiling.
 - Mop sink base at quarry tile.
 - All sinks (multi-compartment, hand, mop and prep) to FRP/tile walls.
 - Paper towel dispensers & soap dispensers to FRP/tile walls.
 - Provide a continuous bead of aluminum GE SCS1009 silicone at the following locations:
 - Stainless closer pieces, at sides of cooler walls - to cooler walls.
 - Stainless or aluminum plate closure pieces to diamond plate at cooler walls.
 - Diamond plate panel seam joints.
 - Diamond plate perimeter to cooler walls.
 - Base of diamond plate to quarry tile cove base.
 - Stainless closure panel, at top of cooler walls, to cooler walls.
 - Top of quarry tile cove base to cooler walls at inside of cooler.
 - Cooler wall/diamond plate penetrations.
 - Cooler door hinges and handles to diamond plate. DO NOT caulk door locking unit.
 - Stainless wrap at hollow metal door frame.
 - Stainless mop surround to stainless corners on mop sink.
 - Base of stainless corner pieces to schluter strip at base.
 - Exit door threshold perimeters. To frame and floor, interior and exterior.
 - Provide a continuous bead of dark gray GE SCS2000 silicone at the following locations:
 - Base of hollow metal door jambs to quarry tile floor.

B. Managers Office:

- Provide a continuous bead of white GE SCS1700 silicone at the following locations:
 - Ceiling grid to FRP wall panels.
 - Perimeter of manager's desk to FRP wall panels.
 - Hollow metal door frame to FRP wall panels.
 - Top and ends of coat hanger bracket to FRP base.
 - Base of FRP wall panels to quarry tile base.
 - Ceiling tile wire/pipe penetrations.
 - FRP inside corners to FRP wall panels. Both sides of corner piece.
 - Base of FRP wall panels to quarry tile.
- Provide a continuous bead of black or light bronze (use color of safe) GE SCS2000 silicone at the following locations:
 - Base of safe to floor.

C. Cooking Area:

- Provide a continuous bead of white GE SCS1700 silicone at the following locations:
 - Top of wall tile to sheetrock ceiling.
 - Ceiling diffusers perimeters to sheetrock ceiling.
 - Ceiling pipe penetrations.
 - Wall tile to aluminum walk thru surround.
 - Tile wall penetrations/escutcheons perimeters.
 - FRP wall panels to sheetrock ceilings.
 - FRP wall panels to aluminum end wall plates.
 - FRP inside corners to FRP wall panels. Both sides of corner piece.
 - Sink to white wall tile.
 - Paper towel dispenser/soap dispenser to white tile.
 - POS/Serving counter to wall tile.
 - Stainless shelf behind grill to wall tile.
 - Faucets to ceramic wall tile.

- Provide a continuous bead of aluminum GE SCS1009 silicone at the following locations:
 - Joint between hood and closure skirt.
 - Joint between hood support and hood. Both sides.
 - Connection joint between stainless shelf behind grill.
 - Hood to tile walls & sheetrock ceiling.
 - Hood gusset to wall tile on both sides.
 - Sink to bronze wall tile.
 - Paper towel dispenser/soap dispenser to bronze tile.
 - DML counter to bronze tile.
- Provide a continuous bead of dark gray GE SCS2000 at the following locations:
 - Base of equipment to concrete curbs/quarry tile.
- Provide a continuous bead of bronze GE SCS2097 at the following locations:
 - Ceramic tile inside corners.
 - Ceramic tile to aluminum end wall plates.

D. Restrooms:

- Provide a continuous bead of white GE SCS1700 silicone at the following locations:
 - Top of FRP to sheetrock ceiling or top of FRP trim to sheetrock wall.
 - Perimeter of toilets/urinals to floor or FRP.
 - Perimeter of mirror to FRP.
 - Sink to wall.
 - Perimeter of paper towel/garbage unit to wall.
 - Toilet paper/napkin disposals units to walls.
 - Stainless shelf to wall.
 - Wall penetrations under sink and or escutcheons to perimeters.
 - Hollow metal door frames to FRP.
 - Base of FRP wall panels to top of wall base.
 - FRP inside corners to FRP wall panels.
- Provide a continuous bead of black GE SCS2000 silicone at the following locations:
 - Base of black rubber wall base to floor.
- Provide a continuous bead of dark gray GE SCS2000 silicone at the following locations:
 - Base of hollow metal door frames to floor.

E. Dining area:

- Provide a continuous bead of white GE SCS1700 silicone at the following locations:
 - Wall tile to sheetrock walls.
 - Perimeter of aluminum storefront/windows/entrances to sheetrock walls.
 - Wainscot wall panels (Stonewood or other) to painted walls.
 - Diffuser/louvers perimeters to sheetrock walls.
 - Hollow metal door frames to painted walls - if needed.
 - Frame of service line counter to tile (joint to be caulked behind front face panels of counter).
 - Wall tile at serving line wall to POS counter.

- Provide a continuous bead of black GE SCS2000 silicone at the following locations:
 - Base of black rubber to floor (concrete or quarry tile) and gyp. bd. wall.
 - Wainscot (Stonewood or other) wall panels to sill of aluminum storefront/ windows.
 - Vertical joints of wainscot (Stonewood or other) wall panels to frames/painted walls/tile (ONLY if joint is uneven or plywood is showing).
 - Stonewood panels at serve line.

- Provide a continuous bead of aluminum GE SCS1009 silicone at the following locations:
 - Base of garbage surround to floor.

- Provide a continuous bead of Dow 795 silicone at the following locations:
 - Sill of aluminum storefronts to concrete or tile floor. Color to be determined per store to match storefront (Charcoal/Anodized Aluminum/Dark Bronze).

F. Utensil Counter:

- Provide a continuous bead of aluminum GE SCS1009 silicone at the following locations:
 - Stainless countertop to backsplash. Horizontal & vertical joints.
 - Base of Coke machine to countertop.
 - Perimeter of tea drain tray to countertop.
 - Stainless backplash to white tile walls/painted walls.

- Provide a continuous bead of white GE SCS1700 silicone at the following locations:
 - Coke line bundle to PVC cap.

G. Fire Rated Walls:

- Provide a continuous bead of 3M 25WB+ at the following locations:
 - Wall/ceiling penetrations in rated walls.

H. Exterior Joints:

- Provide a continuous bead of Tremco Dymeric limestone urethane sealant at the following locations:
 - Sidewalk/concrete expansion joints.
- Provide a continuous bead of Dow 795 silicone or Tremco Dymeric 240 FC at the following locations:
 - Hollow metal door frames.
 - EIFS to abutting services.
 - Penetrations in EIFS.
 - Face brick or block control joints.
 - Perimeter of Aluminum Storefronts.

*Colors to be determined per store to match adjacent material colors. Verify with Chipotle Construction Manager and Architect.

 - For "Fog" EIFS use Tremco - "Natural White"
 - For "Knight's Armor" EIFS use Sonneborn - "Charcoal Gray" #276-U
 - For white brick use Tremco - "China White"
- Provide a continuous bead of aluminum GE SCS1009 silicone at the following location:
 - CO2 fill port stainless box.
 - Faucet for hose. (Please note: color to be determined per store. Verify with Chipotle Construction Manager and Architect).



CLIENT:



CHIPOTLE MEXICAN GRILL, INC.
PO BOX 182966
COLUMBUS, OH 43218-2966
TELEPHONE: (614) 318-2492
INTERNET: WWW.CHIPOTLE.COM

COPYRIGHT 2024
THIS DRAWING IS AN INSTRUMENT OF SERVICE AND AS SUCH REMAINS THE PROPERTY OF CHIPOTLE MEXICAN GRILL, INC. PERMISSION FOR USE OF THIS DOCUMENT IS LIMITED AND CAN BE EXTENDED ONLY BY WRITTEN AGREEMENT WITH CHIPOTLE MEXICAN GRILL, INC.

PROJECT INFORMATION:

STORE NO.: 4757
"ANDERSON IN"
S SCATTERFIELD RD & 59TH STREET
ANDERSON, IN 46013

SEAL:



July 25, 2024

MATTHEW M. WILKUS
LICENSE #AR11700110
(EXPIRES 12/31/2024)

PROJECT NO. 2022-0494
DRAWN BY RDB
CHECKED BY

ISSUE RECORD:
12/12/2023 PERMIT SET
06/19/2024 BID SET
07/24/2024 CONSTRUCTION SET

REVISIONS:

1 05/20/2024 DB UPDATES

TITLE:

ARCHITECTURAL
SPECIFICATIONS

SHEET NUMBER:

G013

2.2 In-Line Side Sliding Automatic Window and Air Curtain

- A. GC to use specification called out on storefornt details sheet and/or as directed by Tenant Arch PM.

• Quikserv Custom Automatic Side Sliding Window (Model: SST-4035E-CHIPOTLE): 45'-1/2"W x 41-3/4"H window with 17'-3/4" tall transom and (2) sidelights at 29' 1/4"W x 41-3/4"H; Complete Unit Size 104"W x 59-1/2"H

1. Service Opening: 19"W x 29-3/4"H
2. Finish: Dark Bronze Anodized
3. Glass: 1" Clear Tempered unit + Low E (Solarban 60e) for fixed and moving panel, sidelights and transom
4. 'CHIPOTLE' package includes pre-wired air curtain with relay to sync operation with window.
a. Arch PM to verify if heated or ambient air curtain is required per Tenant assignment. Air Curtain mounts to transom.
i. Heated Air Curtain: Model: QSV1025EJ-040-BK
ii. Ambient Air Curtain: Model: QSK1025AA-BK
5. Refer to interior elevations (A700s) for direction of opening for ordering.

• ReadyAccess Automatic Side Sliding Window: 47'-1/2"W x 43-1/2"H window with 16" tall transom and (2) sidelights at 28' 1/4"W x 59-1/2"H; Complete Unit Size 104"W x 59-1/2"H

1. Service Opening: 19"W x 35"H
2. Finish: Dark Bronze Anodized
3. Glass: 3/4" Clear Tempered unit + Low E (Solarban 70XL) for fixed & moving panel, sidelights and transom
4. Arch PM to verify if heated or ambient air curtain is required per Tenant assignment.
a. Heated Air Curtain: Model: AA300 (replaces transom)
b. Ambient Air Curtain: Model: AA100 (split transom)
5. Refer to exterior elevations (A300s) for direction of opening for ordering.

B. Alternate California Code Option

1. ReadyAccess: Window 47'-1/2" W x 35-3/4"H with double-split transom for air curtain and 10" and (2) sidelights at 28'-1/4"W x 59-1/2"H; Complete Unit Size 104"W x 59-1/2"H
a. Service Opening: 15'-1/4"W x 28"H, limited to meet CA code.
b. Ambient Air Curtain, AA100, and relay switch kit included with the West Coast Window package.

2. Quikserv Model: SS-4035-E-CHIPOTLE-CALI, same as above except as noted.
a. Service Opening: 28"W x 15-3/8"H, limited to meet CA code.
b. 'CHIPOTLE' package includes pre-wired ambient air curtain with relay to sync operation with window Model: QSK1025AA-BK. Air curtain mounts to transom.

C. Alternate Impact-Resistant and Florida Product Approved Option, Miami Dade Horizontal Bi-Parting Impact Slider

1. Quikserv Model: BP-7241E-IP-CHIPOTLE, Complete Unit Size: 72"W x 41"H.
a. Service Opening: 29'-1/2"W x 27"H
b. Rough Opening: 72'-1/2"W x 41'-1/2"H
c. Glass: Impact Resistant Glass
d. 'CHIPOTLE' package includes ambient air curtain
i. Ambient Air Curtain: Model: QSK1025AA-BK, Part Number: 9345.
ii. Do not mount directly to window, mount on wall above.
e. Miami-Dade NOA #18-0814.02

2.3 Electrical Requirements

- A. Quikserv Electrical Windows: 120V / 60 Hz, 20-amp branch circuit, single phase. Power supplied through base of window. Conforms to UL Standard 325 – Certified to CAN/CSA C22.2 NO. 247. Confirm with Electrical Drawings.

1. Heated Air Curtain for Custom Side Sliding Window (Model: SS-4035-E-CHIPOTLE)
a. Separate 230V circuit and Power Supply required for heated air curtain. Air curtain pre-wired through window frame with power supply routed to base of window. Confirm with Electrical Drawings.
2. Ambient Air Curtain for Custom Side Sliding Window (Model: SS-4035-E-CHIPOTLE) and Alternate California Code Option: Model: SS-4035-E-CHIPOTLE-CALI
a. Separate circuit not required. Window pre-wired to power and sync operation with air curtain.
3. Ambient Air Curtain for Alternate Impact-Resistant and Florida Product Approved Option (Model: BP-7241E-IP-CHIPOTLE):
a. Connect to main control board on window to power and synchronize operation with opening and closing of window.

B. ReadyAccess Electrical Windows: 115V / 60 Hz, 15-amp dedicated circuit required. Run power to header on fixed panel side.

1. AA300 Heated Air Curtain
a. Separate 208V /60 hz /40-amp single phase circuit required.
2. AA100 Ambient Air Curtain (Standard and CA window)
a. Separate 120V / 60Hz / 15-amp single phase circuit required. Run power to center of window above header.

3.1 Installation

- A. Install in accordance with manufacturer's instructions.
B. Install pass-thru windows plumb, level, square, true to line, and without warp or rack. Maintain dimensional tolerances and alignment with adjacent Work.
C. Install thermal isolation where components penetrate or disrupt building insulation. Pack fibrous insulation in shim spaces at perimeter of assembly to maintain continuity of thermal barrier.
D. Install pass-thru window components weathertight.
E. Anchor pass-thru windows securely in place to supports. Use attachment methods permitting adjustment for construction tolerances, irregularities, alignment, and expansion and contraction.
F. Separate aluminum from other metal surfaces with bituminous coatings or other means approved by Architect.
G. Coordinate installation of related sheet metal flashing as specified in Section 07 62 00 - Sheet Metal Flashing and Trim.
H. Install perimeter joint sealants as specified in Section 07 91 23 - Backer Rods.

SECTION 08710 - DOOR HARDWARE

1.1 General: Provide door hardware as shown and specified.

- A. Standards: Materials and installation shall conform to the following:
1. ANSI A117.1-2009 Accessible and Usable Buildings and Facilities.
2. ANSI/BHMA A156 Series Builders Hardware

- B. Quality Assurance:
1. Codes and standards: Provide hardware complying with local Building Code requirements and the Tenant's standards for keying and security systems.
2. Project scheduling: Performed by an Architectural Hardware Consultant (AHC).
3. Package each item of hardware and each lockset, complete with all screws, anchors, installation instructions and templates. Identify package indexing with corresponding item number of the hardware schedule.
4. After hardware schedule acceptance, provide necessary templates or physical hardware to required trades for cutting, reinforcing, or preparing their products to receive hardware. Furnish templates to metal door manufacturer's.

2.1 Materials:

- A. No substitutions allowed. Requirements for manufacturer, design, grade, function, finish, size and other distinctive qualities of each type of door hardware are indicated on the drawings.

- B. Review the keying system with the Tenant and provide the type required.

3.1 Installation

- A. Install each hardware item in strict accordance with manufacturer's installation instructions and recommendations. Securely fasten all attached parts. Fit faces of mortised parts snug and flush. Verify operating parts move freely and smoothly without binding or sticking, without excessive clearance.

- B. Set units level, plumb and true to line and location. Adjust and reinforce attachment substrate as required for proper installation and operation. Drill and countersink units that are not factory prepared for anchorage fasteners. Space fasteners and anchors in accordance with industry standards.

- C. Mount hardware units at heights indicated in DHI "Recommended Locations for Builders Hardware", unless otherwise required to comply with requirements of governing codes and regulations. Conform to ANSI A117.1 and ADAGG guidelines for accessibility.
1. Top Butts: 5 inches; top of butt from head of frame.
2. Middle Butts: 3'-2", centerline from finish floor.
3. Bottom Butts: 5 inches; finish floor to bottom of butt.
4. Locks: centerline from finish floor per hardware schedule.
5. Knobs: 3'-2", centerline from finish floor.
6. Pulls: centerline from finish floor per hardware schedule.
7. Pushes: centerline from finish floor per hardware schedule.

SECTION 08800 - GLAZING

1.1 General: Provide glass and glazing as shown and specified.

- A. Standards: Materials and installation shall conform to the following:
1. CPSC 16 CFR Part 1201 (1-91)"Safety Standard for Architectural Glazing Materials."
2. GANA "Glazing Manual - 1990."

B. Quality Assurance:

1. Codes and standards: Provide type of glass and glazing products that comply with ANSI Z97.1 and testing requirements of 16 CFR Part 1201 for category II materials. Comply with all applicable codes, standards and regulations that control safety glazing materials and installation.
2. System Performance: Provide glass and glazing that has been produced, fabricated and installed to withstand normal thermal movement, wind loading and, where applicable, impact loading, without failure including loss or breakage of glass, failure of glazing sealants or gaskets to remain watertight and airtight, deterioration of glass and glazing materials and other defects in the work.
3. Installation: Performed only by experienced glaziers.

C. Warranty:

1. Insulating glass: Five years from date of installation against defects that materially obstruct vision through the glass or affect thermal and physical integrity.

2.1 Materials:

- A. Glass:
1. Float Glass (FG): 1/4" thick clear float glass.
2. Tempered Glass (TG): 1/4" and 1/2" thick clear, tempered safety glass, free-of-tong marks.
3. Insulating Glass (IGL): 1" thick clear, low-e tempered sealed glass; 1/4" thick interior and exterior glass lites with 1/2" aluminum desiccated dual sealed air space; with the following characteristics:
a. Low-emissivity coating on #2 surface.
b. Visible Light Transmittance: 64% - 70%
c. Visible Light Reflectance - Outdoors: 9%-11%
d. Solar Energy Transmittance: 32%-34%
e. Solar Energy Reflectance-Outdoors: 30%-34%
f. U-Value - Winter Night: 0.29
g. U-value - Summer days: 0.28
h. Solar Heat gain Coefficient: 0.25-0.39
i. Shading Coefficient: 0.43-0.45
j. Manufacturers/Products:
i. AGC/Comfort Ti-AC40, or similar to meet code
ii. Sun Guard/SN-68, or similar to meet code
iii. PPG/Solarban 60, or similar to meet code
iv. Viracore/VE1-2M, or similar to meet code
4. Spandrel Glass (SG) 1/4" thick, Spandrel Ceramic Glass, (Color: GrayBlack or as noted on drawings) by Old Castle Building Envelope (419) 666-2000, Contact: Doug Dewar
5. Frosted Window Film, 3M Dusted Crystal Translucent Window Film. Apply on the interior side of glazing.

- B. Glazing Materials:
1. Glazing Sealants: Provide elastomeric glazing sealants suitable for applications indicated; compatible with one another and with other materials they will contact, complying with ASTM C920.
2. Glazing Tape: Provide preformed, non-staining and non-migrating elastomeric tape, as recommended by tape and glass manufacturers for application indicated, complying with ASTM C 1281.
3. Glazing gaskets: Provide manufacturer's standard snap-on aluminum stops and neoprene, vinyl or EPDM glazing gaskets.
4. Provide setting blocks, spacers and edge blocks of material, size, and shape complying with referenced glazing standard, and compatible with surfaces contacted in installation.

C. Fabrication: Factory fabricate and size all glass.

3.1 Installation

- A. Preparation:
1. Field verify measurements and conditions of installation.
2. Examine all details. Provide proper fitting to details indicated.
3. Glazing channel dimensions shown are intended to provide for necessary bite on glass, minimum edge clearance and adequate glazing materials thickness, with reasonable tolerances. Adjust as required by job conditions at time of installation.

- B. Install glass and glazing in accordance with the GANA "Glazing Manual" and glass manufacturer's recommendations.
1. Install insulating glass units to comply with recommendations by Sealed Insulating Glass Manufacturers Association (SIGMA).

- C. Install setting blocks of proper size at quarter points of sill rabbet. Provide spacers as required.

- D. Install glazing sealants, tapes and gaskets in accordance with manufacturer's recommendations. Set glass without springing and install securely to prevent rattling or breakage.

- E. Protect glass from breakage during remaining construction. Do not remove non-permanent labels until final acceptance.

DIVISION 9 -- FINISHES

SECTION 09260 - GYPSUM BOARD SYSTEMS

1.1 General: Provide gypsum board systems as shown and specified.

- A. Standards: Materials and installation shall conform to the following:
1. GA 214-90 "Levels of Gypsum Board Finish."
2. GA-216 "Specifications for Application and Finishing of Gypsum Board."
3. USG "SA923 Drywall/Steel Framed Systems."

2.1 Materials:

- A. Manufacturer: United States Gypsum Co. (USG), (800) 874-4968, internet www.usg.com.

- B. Metal framing: Comply with ASTM C 754 and ASTM C 645 for materials and sizes.

1. Partition metal framing:
a. Studs: Galvanized steel, C-shaped, sizes indicated, 20 gage "ST20"
b. Runners: Match studs, type recommended by stud manufacturer for floor and ceiling support of studs. Provide flexible ceiling runners for full height metal stud framed partitions continuous from floor to underside of structural members or deck above.

- C. Ceiling and Soffit metal framing/suspension systems:
1. Small areas: Metal stud framing of appropriate size and gage for spans indicated.
2. Large areas: Furring channel "Grillage" or "Direct Suspension System" designed for concealed support of gypsum board ceilings, of proper type for use indicated.
3. Furring members: 20 gage, galvanized steel screw type, hat-shaped furring.

- D. Gypsum board panels: USG "Sheetrock" complying with ASTM C1396, tapered edge face panels, 48" wide, in maximum lengths available to minimize end joint conditions, 5/8" thick.
1. General use panels: Sheetrock Regular panels.
2. Fire rated panels: Sheetrock Firecore Core panels.
3. Water-resistant: panels: Sheetrock HUMITEK panels.

- E. Cement board: USG DUROCK Cement Board, 5/8" thick x manufacturer's standard width, complying with ANSI A118.9, and in maximum lengths available to minimize end-to-end butt joints.

- F. Fasteners: USG Type "S" bugle head screws for metal framing, USG Type "W" bugle head screws for wood framing, manufacturer's recommended length for panel thickness indicated.

- G. Trim: Galvanized steel with knurled and perforated flanges. USG Dur-A-Bead corner bead, No. 2008 casing bead metal trim, No. 093 Control Joint.

- H. Joint treatment: USG Joint Treatment System, utilizing "Sheetrock Brand Joint Tape", and "Sheetrock Brand Setting-Type (DURABOND)" compound for tape bedding and topping.

- I. Adhesives: USG "Sheetrock Brand Setting-Type (DURABOND) 210 or 90" compound for tape bedding and topping.

- J. Acoustical sealant: USG Sheetrock Acoustical Sealant, water-base type, gunnable sealant for sealing sound-rated gypsum board systems.

- K. Sound attenuation insulation: USG Thermafiber unfaced 3-1/2" thick, mineral fiber insulating batts/blankets; standard lengths and widths required to coordinate with spaces insulated.

3.1 Installation

- A. Install metal wall and partition framing and ceiling suspension/ support systems in accordance with USG Bulletin SA 923 and complying with ASTM C754.
1. Ceiling suspension/ support systems: Metal furring system/direct suspension or steel stud framing system.
2. Wall and partition framing:
a. Install steel studs per schedule or at spacing indicated with bottom and top runner tracks anchored to substrates. Provide flexible ceiling runner tracks at full height partitions.
b. Terminate partition stud system 4" above ceilings, except where indicated to be extended to structural support or roof deck above. Brace tops of partition framing to structure or roof deck at maximum 4'-0" on center spacing.
c. Frame openings more than 2'-0" wide with two 20 gage studs at each jamb.
d. Coordinate the installation of supplementary blocking and nailers, provided under Section 06100 work, to support shelving, millwork, toilet accessories, and similar work that cannot be adequately supported by gypsum board alone.

- B. Application and Finishing: Install and finish gypsum board to comply with ASTM C 840 and Gypsum Association GA 216 "Recommended Specifications for the Application and Finishing of Gypsum Board."
1. Screw fasten all gypsum board panels.
2. Metal Trim: Install metal corner beads at external corners of gypsum board work and metal trim wherever edge of gypsum board would be exposed. Use longest practical lengths.
3. Control Joints: Locate and install control joints in accordance with USG Bulletin SA923 "Good Design Practice" recommendations.

- C. Acoustical Treatment:
1. Where sound-attenuation insulation is indicated, seal gypsum board construction at perimeters, control joints, junction boxes, openings and penetrations with a continuous bead of acoustical sealant including a bead at both faces of partitions.
2. Install sound attenuation insulation at scheduled partitions and ceilings. Install insulation in single layer of required thickness. Extend full thickness over entire area to be insulated. Cut and fit tight around obstructions. Fill all voids.
3. At openings and cutouts, fill open spaces between edges of gypsum board and fixtures, cabinets, ducts, and other flush or penetrating items, with continuous bead of acoustical sealant.
4. Seal sides and backs of electrical boxes to completely close up openings and joints with a bead of acoustical treatment.

D. Finishing:

1. Comply with manufacturer's instructions for mixing, handling, and application of materials. Apply treatment at joints both directions, at flanges of trim accessories, penetrations of gypsum board (electrical boxes, piping, and similar work), fastener heads, surface defects, and elsewhere as indicated. Apply in manner that will result in each of these items being concealed when applied decoration has been completed.
2. Apply joint tape at joints between gypsum boards, except where trim accessories are indicated.
3. Interior Exposed Gypsum Board Finish: Level 5 Finish.
a. Locations: Typical for all walls and ceilings, unless otherwise indicated
b. Finish interior gypsum board by applying the following joint compounds in four coats (not including prefill of openings in base), and sand between coats and after last coat:
c. Embedding and First Coat: Setting-type joint or taping compound.
d. Fill (Second) Coat: Setting-type topping compound.
e. Fill (Third) Coat: Setting-type topping compound.
f. Finish (Fourth) Coat: Skim coat entire surface.
4. Interior Concealed Gypsum Board: Level 3 Partial Finishing.
a. Finish concealed gypsum board construction that requires finishing same as exposed gypsum board construction, except the third coat and sanding can be omitted.

- E. Cement Board: Install cement board as a 16" high base at all kitchen and kitchen cook line wall types as indicated on drawings.

SECTION 092816 - GLASS-MAT FACED GYPSUM BACKING BOARDS

1.1 General: Provide Fiberglass-mat faced, moisture resistant gypsum backer board as shown and specified.

- A. Standards: Materials and installation shall conform to the following:
1. ASTM C840 Standard Specification for Application and Finishing of Gypsum Board.
2. ASTM C1002 Standard Specification for Self Piercing Tapping Screws for the Application of Gypsum Panel Products or Metal Plaster Bases to Wood Studs or Steel Studs
3. ASTM C1178 Standard Specification for Glass Mat Water-Resistant Gypsum Backing Panel
4. ASTM D3273 Standard Test Method for Resistance to Growth of Mold on the Surface of Interior Coatings in an Environmental Chamber
5. ASTM D6329 Standard Guide for Developing Methodology for Evaluating the Ability of Indoor Materials to Support Microbial Growth Using Static Environmental Chambers.
6. ASTM E96 Standard Test Methods for Water Vapor Transmission of Materials
7. Tile Council of North America, Inc. (TCNA): TCA Handbook for Ceramic Tile Installation, Current Edition.

2.1 Materials:

- A. Manufacturer: Georgia-Pacific Gypsum LLC, (800) 225-6119, internet: www.bulldgp.com

- B. Fiberglass-Mat Faced Gypsum Backing Board: DensShield Fireguard Tile Backing Board complying with ASTM C1178, Type X, Square edges, 4" wide in maximum lengths available to minimize end joint conditions, 5/8" thick. Surfacing: Coated fiberglass mat on face, back and long edges.
1. General use panels: 5/8" DensShield Fireguard Tile Backer, Georgia-Pacific Gypsum.

- C. Fasteners: Screws meeting ASTM C1002, with corrosion resistant treatment. Size and type per manufacturer's recommendations:
1. Walls (Steel Frame): Bugle head, fine thread, sharp point rust resistant drywall screw
2. Walls (Walls Frame): Bugle head, coarse thread, sharp point rust resistant screw

- D. Metal Framing, Trim, joint treatment, adhesives, acoustical sealant, and sound attenuation insulation: Refer to Section 09260 Gypsum Board Systems

3.1 Installation

- A. Install DenShield at all tile walls excluding hood area as indicated on drawings.

- B. General: Install in accordance with ASTM C840, manufacturer's recommendations and TCA Handbook for Ceramic Tile Installation.
1. Manufacturers Recommendations: refer to Current "Product Catalog", Georgia Pacific Gypsum.
a. Attach DensShield Tile Backer with grey side facing the interior. Tile should be applied on the grey coated side of DensShield Tile Backer. Cut panel to required size and make cutouts. Fit ends and edges closely. Do not leave gaps between panels.
b. DensShield Tile Backer may be cut by using a utility knife to score, then snap, working from the grey face side.
c. For walls, when used as a tile substrate a minimum 20-gauge steel or wood framing should be spaced no greater than 24" o.c. for 5/8" DensShield Tile Backer. Board can be applied horizontally or vertically.
d. Fasteners shall be spaced 6" o.c. for walls for wood and steel framing. Do not countersink. Drive fasteners flush with grey coated surface. See manufacturer installation Fastener Guide for proper selection.
e. In all corners, imbed with a bead of flexible sealant when installing panels into corner. Apply self-adhesive 2" wide fiberglass mesh tape and bed tape on all joints and corners with material used to set tiles.
f. Caulk or seal fixture/plumbing penetrations and abutments to dissimilar materials.
g. Do not use all purpose joint compound or tape in wet areas.
h. Do not apply DensShield Tile Backer directly to concrete or masonry block. Framing or furring of the walls is necessary.
i. DensShield Tile Backer should not be used for exterior installations.
j. DensShield Tile Backer panels should not be used as a base for nailing and mechanical fastening.
k. DensShield Tile Backer has a built in moisture barrier. Never install vapor retarders directly behind DensShield Tile Backer panels. In retrofit applications, some paints or other wall coverings may constitute a vapor barrier; remove or effectively penetrate these coverings prior to installing DensShield Tile Backer panels.

- C. Refer to Section 09260 Gypsum Board Systems for additional installation and sound treatment instructions

SECTION 09330 - QUARRY TILE

1.1 General: Provide quarry tile flooring and base as shown and specified.

- A. Standards: Materials and installation shall conform to the following:
1. ANSI A137.1 "Ceramic Tile."
2. TCA "Handbook for Ceramic Tile Installation."

2.1 Materials:

- A. Manufacturers:
1. Quarry Tile: Daltile, (877) 556-5728, internet: http://daltile.com
a. For ordering purposes, email all orders to chipotle@daltile.com
2. Waterproofing, Setting and Grouting Materials:
a. Setting and Grouting Materials and Tile Base Membrane: Mapei
i. For ordering purposes, email all orders to chipotle@daltile.com
ii. For technical questions, contact Mapei, (800) 992-6273, internet: www.mapei.com

- B. Quarry Tile: Daltile 6" x 6" x 1/2" Quarry Textures with 5" base as scheduled on finish plan and appropriate trim; Color: "Ashen Gray" OT03
1. Entire Kitchen Area: Provide non-abrasive finish quarry tile.
2. Rest Rooms: Provide non-abrasive finish quarry tile.
3. Outside Corner Cove Base (Kitchen): #QC- (L or R) 3565 5" x 6"
4. Inside Corner Cove Base: #QB-3565 1" x 5"
5. Bullnose Coveless Base: #Q-1665, 6" x 6".
6. Bullnose Corner Coveless Base: #QCRL-1665, 6" x 6".

- C. Waterproofing for elevated floor slabs: Mapei, Mapelastic AquaDefense, Premium Waterproofing and Crack Isolation Membrane
D. Setting Adhesive: Mapei, Ultraflex 3, Color: Gray
E. Grout: Mapei, Kerapoxy IEG CQ, Color: #9, "Gray", 1/4" grout joints.
F. Quarry Tile Base Membrane: Mapei, Mapelastic AquaDefense, Premium Waterproofing and Crack Isolation Membrane

3.1 Installation

- A. Preparation: Clean substrate surfaces, scheduled to receive quarry tile, thoroughly and remove all coatings that may impair bond.
1. Center tile fields both directions in each floor area. Adjust layout to minimize tile cutting. Avoid tile less than one-half size. Locate cuts to be least conspicuous.
2. Maintain units uniformly "in plane." Provide straight, uniform joint widths and grout lines.

- B. Elevated Floor Slabs: Install waterproofing membrane at elevated floor slab surfaces scheduled to receive quarry tile floor finish. Install membrane materials in accordance with manufacturer's installation instructions to produce a waterproof membrane of uniform minimum 30 mil thickness bonded securely to substrate.
1. Extend waterproofing up vertical wall surfaces minimum 10" high.
2. Extend membrane down into floor drain flanges to assure continuous waterproofing at drainage points.

- C. Wet Areas: Install waterproofing membrane at all quarry tile wall base. Install membrane materials in accordance with manufacturer's installation instructions to produce a waterproof membrane of uniform minimum 30 mil thickness bonded securely to substrate.
1. Extend waterproofing up all vertical wall surfaces receiving quarry tile base minimum 10" high. Extend waterproofing membrane 10" minimum horizontally from all vertical wall surfaces receiving quarry tile base.

- D. Installation: Install, grout and clean ceramic tile in accordance with referenced TCA installation details and ANSI standard specifications for setting methods scheduled.
1. Floors: latex-portland cement mortar on concrete; TCA detail F113 and ANSI A108.5, grout ANSI A108.10.
2. Base: Latex-portland cement mortar on cement board.

SECTION 09340 - CERAMIC TILE

1.1 General: Provide ceramic wall tile as shown and specified.

- A. Standards: Materials and installation shall conform to the following:
1. ANSI A137.1 "Ceramic Tile."
2. TCA "Handbook for Ceramic Tile Installation."

2.1 Materials:

- A. Manufacturers:
1. Ceramic Tile and Accent Tile: Daltile, P: (877) 556-5728, internet: http://daltile.com
a. For ordering purposes, email all orders to chipotle@daltile.com

- B. Ceramic Tile:
1. Kitchen Tile, or as noted in plans, Series - Finish Line Glazed Ceramic Tile:
a. Color - White FL90, Semi-Gloss, Size - 4 x 16, Pattern - Stacked Bond
2. Accent Tile, Series - Color Wheel Glazed Ceramic
a. Color - Chipotle Brick Metallic 1.0 #9999710686, Size - 3 x 12, Pattern - Stacked Bond
b. Alternate Accent Tile only when approved by Arch PM and Chipotle DM
i. Series - Remedy, Color - Alchemy RD25, Size - 2 x 9, Pattern - Stacked Bond
ii. Series - Marrazzi, Color - Artesen AT25, Size - 2 x 4, Pattern - Brickjoint Mosaic

- C. Setting Adhesive: Thinset Mortar, Mapei, Ultraflex LFT - Gray

- D. Grout:
1. Kitchen Tile or as noted in plans
a. Mapei, Series - Flexcolor CQ - Gray #09, 1/8" grout joints.
2. Accent Tile
a. Mapei, Series - Flexcolor CQ - Chocolate #07, 1/8" grout joints.

3.1 Installation

- A. Preparation: Clean substrate surfaces scheduled to receive ceramic tile thoroughly and remove all coatings that may impair bond.
1. Protect surrounding work from damage.
2. Remove any curing compounds or other contaminants.
3. Vacuum clean surfaces and damp clean.
4. Install cementitious backer board or glass-mat faced gypsum backing board as indicated in drawings in accordance with ANSI A108.11 and board manufacturer's instructions. Tape joints and corners, cover with skim coat of dry-set mortar to a feather edge.
5. Prepare substrate surfaces for adhesive installation in accordance with adhesive manufacturer's instructions.

- B. Kitchen:
1. Install, grout and clean ceramic tile in accordance with referenced TCA installation details and ANSI standard specifications for setting methods scheduled.
2. Lay tile in horizontal stack bond, following detail drawings for layout considerations. Horizontal rows of tile shall be full-height courses, unless noted otherwise.
3. Arrange pattern so that a full tile or joint is centered on each wall horizontally and that no tile less than 1/2 width is used at the ends of the wall. Exception: when one end of the wall is a tile-to-gypsum board transition. Do not interrupt tile pattern through openings.
4. Use specified stainless steel corner guards at tile-to-tile and tile-to-FRP outside corners.
5. Use corner bead of 100% silicone sealant, color to match grout, at inside corners where tile meets tile.
6. Use corner bead of 100% silicone sealant, white, at inside corners where tile meets paint gyp. board, tile meets FRP or tile meets aluminum.
7. Cut and fit tile to penetrations through tile, leaving sealant joint space. Place tile joints uniform in width, subject to variance in tolerance allowed in tile size. Make joints watertight, without voids, cracks, excess mortar, or excess grout.
8. Sound tile after setting. Replace hollow sounding units.
9. Keep expansion joints free of adhesive or grout. Allow tile to set for a minimum of 48 hours prior to grouting. Apply sealant to junction of tile and dissimilar materials and junction of dissimilar planes. Refer to section 07900 Joint Sealers.
10. Clean tile and grout surfaces.



CLIENT:



CHIPOTLE MEXICAN GRILL, INC.
PO BOX 182966
COLUMBUS, OH 43218-2966
TELEPHONE: (614) 318-2982
INTERNET: WWW.CHIPOTLE.COM

COPYRIGHT 2024
THIS DRAWING IS AN INSTRUMENT OF SERVICE AND AS SUCH REMAINS THE PROPERTY OF CHIPOTLE MEXICAN GRILL, INC. PERMISSION FOR USE OF THIS DOCUMENT IS LIMITED AND CAN BE EXTENDED ONLY BY WRITTEN AGREEMENT WITH CHIPOTLE MEXICAN GRILL, INC.

PROJECT INFORMATION:

STORE NO.: 4757
"ANDERSON IN"
S SCATTERFIELD RD & 59TH STREET
ANDERSON, IN 46013

SEAL:



July 25, 2024

MATTHEW M. WILKUS
LICENSE #A#11700110
(EXPIRES 12/31/2024)

PROJECT NO. 2022-0494

DRAWN BY RDB

CHECKED BY

ISSUE RECORD:

12/12/2023	PERMIT SET
06/19/2024	BID SET
07/24/2024	CONSTRUCTION SET

REVISIONS:

1 05/20/2024 DB UPDATES

TITLE:

ARCHITECTURAL
SPECIFICATIONS

SHEET NUMBER:

G015

SECTION 09510 - SUSPENDED CEILING SYSTEMS

1.1 General: Provide acoustical ceiling systems as shown and specified.

- A. Standards: Materials and installation shall conform to the following:
1. CISC "Acoustical Ceilings - Use and Practice."
 2. ASTM C635.
 3. ASTM C636.
- B. Related Sections:
1. 09515 Cementitious Wood Fiber Acoustical Panels: Suspension system.

2.1 Materials:

- A. Manufacturer:
1. USG Interiors, Inc., (800) 950-3839, www.usg.com
 2. Pittcon Industries, (800) 637-7638, www.pittconindustries.com
- B. Ceiling Panels: USG "Sheetrock Lay-In ClimaPlus No. 3270" ceiling panels with white, stipple texture, vinyl facing, 24" x 48" x 1/2".
- C. Light Pocket: Pittcon "LP-700-800", White, Height of cove should be field verified by GC to end on a full tile height.
1. Light pocket can have up to 6 week lead time and should be ordered as soon as possible.
 2. Light pocket endcap should only be installed when the end of the cove is not against a wall.
- D. Suspension System: Provide intermediate duty, structural class, direct hung systems adequate to support light fixtures, ceiling diffusers and other normal accessories.
1. Exposed "Tee" Grid System for use with Lay-In Ceiling panels: USG "Donn DX System" non-fire rated with 15/16" exposed face, cold-rolled galvanized steel with aluminum face cap, white paint finish on exposed surfaces. Provide hemmed edge aluminum wall angles, 15/16" exposed leg, white paint finish matching exposed grid.
 2. Concealed "Tee" Grid System for use with Painted Gypsum Board Ceilings & Soffits or with Cementitious Wood Fiber Acoustical Panels (Tectum): USG "DGLW" Heavy Duty Drywall Suspension System with 1 5/8" deep by 1 1/2" wide main tees and 1 1/2" deep by 1 1/2" wide cross tees.
 3. Hanger Wire: No. 12 SWG galvanized steel wire.
 4. Heavy Duty "Tee" Grid System for use with Felt Baffle Ceiling System: USG Donn Brand DX/L with 15/16" wide face tees, color: black

3.1 Installation

- A. Install acoustical ceiling materials and suspension systems in strict accordance with manufacturer's recommendations, complying with governing regulations and industry standards applicable to the work.
- B. Suspension system installation shall be laser leveled with a maximum surface leveling tolerance of 1/8" in 12'-0".
- C. Install exposed Tee suspension systems with main tees nominally 12 ft long spaced 48 in O.C. and cross tees nominally 4 feet long spaced 24 in O.C.
- D. Install concealed Tee suspension systems with main tees nominally 12 ft long spaced 24 inches O.C. and cross tees nominally 2 ft long spaced 48 in O.C.
- E. Hanger wire shall be spaced 48" O.C. along main tees, at all four corners of light fixtures (where applicable), at midpoint of cross tees adjacent to light fixtures and duct outlets, and adjacent to main tee splices.
- F. Secure wire hangers by looping and wire-tying either directly to building structure or to hangers that are secure and appropriate for substrate.
- G. Provide edge trim molding at perimeter of acoustical ceiling installation and intermediate vertical surfaces. Use maximum lengths. Miter trim corners to Provide tight, accurate joints. Connect moldings securely to substrate surfaces.

SECTION 09653 - RUBBER WALL BASE

1.1 General: Provide resilient rubber wall base as shown and specified.

- A. Standards: Materials and installation shall conform to the following:
1. ASTM D 2240 Rubber - 85 Shore A

2.1 Materials:

- A. Manufacturer: Johnssonite, Inc., (800) 899-8916, Internet: www.johnssonite.com
1. Basis-of-Design Product Rubber Wall Base:
 - a. Resilient Rubber:
 1. .125" (3.17 mm) Thickness
 2. "Black" color
 3. Straight (toeless) or coved as specified on finish plan
 4. Inside and outside corners with 4" returns.
 - B. Alternate Wall Base only when approved by Arch PM and Chipotle DM.
 1. Vinyl Wall Base
 - a. .125" (3.17 mm) Thickness
 - b. "Black" color
 - c. Straight (toeless) or coved as specified on finish plan
 - d. Inside and outside corners with 4" returns.
 - C. Setting Adhesive:
 1. For porous surface applications: Johnssonite 960 Acrylic Cove Base Adhesive.
 2. For non-porous surface applications: Johnssonite 946 Contact Bond Adhesive or polymer based alternative.

3.1 Installation:

- A. Preparation: Clean substrate surfaces scheduled to receive resilient rubber and vinyl wall base thoroughly and remove all coatings that may impair bond. A uniform temperature of at least 65 degrees Fahrenheit shall be maintained for 24 hours before, during and after the installation is completed. The wall base and adhesives shall be conditioned in the same manner. Coiled wall base shall be uncoiled and lay flat for at least 24 hours at 65 degrees Fahrenheit prior to installation. Floor and walls shall be clean, dry, and free of dust, all paints, wallpaper, and all other foreign material, which may affect proper adhesive bonding. Wall base may be installed on interior plaster, gypsum wall board, concrete, masonry, mineral-reinforced cement board or similar porous surfaces. Wall base shall not be installed on surfaces that will be exposed to drastic temperature changes or moisture.
- B. Application: Use a 1/8" square notch trowel to apply adhesive. Allow adhesive to set up and then apply wall base in accordance with manufacturer's instructions.

SECTION 09770 - SPECIAL WALL SURFACING - PHENOLIC INTERIOR WALL PANELS

1.1 General: Provide Stonewood solid phenolic panels and accessories for interior walls and millwork as shown and specified.

1.2 Related Sections:

- A. Section 05400 - Cold Formed Metal Framing
- B. Section 06210 - Finish Carpentry and Millwork
- C. Section 07900 - Joint Sealers
- D. Section 09260 - Gypsum Board Systems
- 1.3 Standards: Materials and construction shall conform to the following:
- A. ASTM D638 - 10 Standard Test Method for Tensile Properties of Plastics.
- B. ASTM D790 - 10 Standard Test Methods for Flexural Properties of Unreinforced and Reinforced Plastics and Electrical Insulating Materials.
- C. ASTM E84 - 12 Standard Test Method for Surface Burning Characteristics of Building Materials.
- D. NEMA Standards Publication LD3-2005. High pressure decorative laminates.

1.4 Design/Performance Requirements:

- A. Design and size of wall panel assemblies including wall panels, mounting system to support weight of panels.
- B. Allow for thermal movements from ambient and surface temperature changes by preventing bucking, opening of joints, overstressing of components, failure of joint sealants, failure of connections, and other detrimental effects. Base calculations on expected movement of material as defined in fabrication guidelines.

1.5 Quality Assurance:

- A. Manufacturer's Qualifications:
1. Sufficient plant facilities to provide quality and quantity of materials as required without delaying progress of work.
 2. Minimum of 40 years of experience in paper saturation of phenolic resin, and producing phenolic paper laminate.
- B. Fabricator:
1. Fabricated by the manufacturer, and/or;
 2. Contracted by the customer, minimum 5 years' experience in fabrication work for the size and complexity of the projects.
- C. Installer
1. Proven professional installer with a minimum of 5 years of documented experience.
 2. Approved by the manufacturer.

1.6 Delivery, Storage and Handling:

- A. Refer to Section 01400 Quality Requirements.
- B. Delivery: Deliver materials in manufacturer's original unopened containers/packages, with labels clearly identifying product name, manufacturer, color/texture and weight.
- C. Storage:
1. Keep panels dry and stored indoors in original packaging until installation.
 2. Store Stonewood panels on a smooth, dry, flat surface, making sure there are no bends or bowing in the load.
 3. Do not store directly on cold concrete floors as moisture may migrate.
 4. Do not store under heating units or air conditioning units.
 5. Keep load stored within outer wrap until use. Remove pallet straps once load is moved to storage area.
 6. Reseal plastic wrap if partial load is used.
 7. Keep foam dividers in place.
- D. Handling:
1. Handle materials in accordance with manufacturer's instructions.
 2. Protect materials during handling to prevent damage.
 3. When moving sheets, lift evenly to avoid dragging panels across each other and scratching the surface. PLEASE TAKE CARE NOT TO SCRATCH THE SURFACE OF THE PANEL DURING HANDLING, MACHINING AND INSTALLATION.

1.7 Warranty:

- A. Limited Warranty: Fibbers warrants Stonewood for a period of 10 years. Refer to www.stonewoodpanels.com for details.

1.8 Project Conditions:

- A. Environmental Limitations: Buildings are to be fully enclosed prior to installation with sufficient heat (70 degrees) and ventilation consistent with good working conditions for finish work.
- B. Maintain environmental conditions (temperature, humidity, and ventilation) within limits recommended by manufacturer for optimum results. Do not install products under environmental conditions outside manufacturer's absolute limits.
- C. Field Measurements: Verify locations of structural members and wall opening dimensions by field measurements before composite wall panel fabrication and indicate field measurements on Shop Drawings.

2.1 Manufacturer:

- A. Fibersen Industries, Inc. PO Box 808, Oconomowoc, WI. 53066. Phone: (262) 567-4427, Fax: (262) 567-4814, Web Site: www.stonewoodpanels.com Email: info@fibersen.com
- B. Made in the United States from materials sourced in the USA.

2.2 Application:

- A. Apply Solid Phenolic Laminate Wall Panels at walls and other surfaces as indicated on the Drawings. Phenolic Wall Panels are architectural wall panels applied over a sheathed stud wall or other solid blocking per Drawings.

2.3 Interior Stonewood:

- A. Material: Solid phenolic laminate panel w/o overlay.
- B. Color: Black ND
- C. Finish: Matte
- D. Standard Size: 48"x96", fabricator to trim height to 47"
- E. Panel Thickness: 5/16", 1/2"
- F. Panel Core: HR Black

2.4 Minimum Material Properties

- A. NEMA Requirements:
- | Description | NEMA Requirements | |
|----------------------------|-------------------|-------|
| Dimensional Change: | 3.11 | |
| Length (Machine Direction) | 0.3% Maximum | 0.25% |
| Width (Cross Direction) | 0.7% Maximum | 0.50% |
| Density (PCF) | 82 | |
- B. Mechanical Properties:
- | Property | NEMA Requirements | |
|------------------------------|---------------------|----------------------|
| Flexural Strength ASTM D-790 | | |
| MD (psi) | 18,000 | 20,000 |
| CD (psi) | 12,000 | 16,000 |
| Flexural Modulus ASTM D-790 | | |
| MD (psi) | 1.6x10 ⁶ | 2.0 x10 ⁶ |
| CD (psi) | 1.4x10 ⁶ | 1.5x10 ⁶ |
| Tensile Modulus ASTM D-638 | | |
| MD (psi) | 18,000 | 18,000 |
| CD (psi) | 12,000 | 13,000 |
- C. Fire Resistance:
- | | Class A (0.250") | Class B (0.250") |
|--|------------------|------------------|
| Flame Spread Index - ASTM E-84 (BLDG): | 5 | 30 |
| Smoke Developed Values - ASTM E-84 (BLDG): | 5 | 105 |
| Fire Rating (Standard Product is Class B): | A | B |
- D. Manufacturing Tolerance:
- | | |
|------------------------------------|----------|
| Thickness (156 to 375) | +/- .020 |
| Thickness (above 375 to 1,000) | +/- .030 |
| CNC Shaped Size (Length - Width) | +/- .020 |
| Drill Diameter | +/- .003 |
| Drill Depth | +/- .020 |
| CNC Hole to Hole | +/- .020 |
| CNC Hole to Edge (1 Oper) | +/- .020 |
| CNC Hole to Edge (2 Oper) | +/- .030 |
| Routing - (Slots Width and Length) | +/- .015 |
| Routing - (Slots Depth) | +/- .020 |

2.5 Accessories (Fasteners):

- A. Panel Fasteners: #10 x 1-1/4" flat phillips head black oxide wood screws to be used with wood blocking and #10 x 1-1/4" flat phillips head black oxide sheet metal screws to be used with sheet metal blocking as recommended by the manufacturer.
- B. Provide exposed fasteners with heads matching color of composite wall panels by means of factory-applied coating.
- C. Fasteners shall be designed to withstand effects of dead load and accommodate hydrothermal expansion/contraction of panel.
- D. Wall Panel Accessories: Provide components required for a complete composite wall panel assembly including trim, flashings, sealants, gaskets, fillers, closure strips, and similar items. Match material and finish of composite wall panels unless otherwise indicated.

3.1 Manufacturer's Execution Instructions:

- A. Compliance: Comply with manufacturer's/fabricator's/supplier's product data, handling and installation instruction/manual, shop drawings, shipping container/package ticket identification, etc.

3.2 Examination:

- A. Verify correct panels received including dimension, tolerance, color/texture.
- B. Verify correct attachment system received for the specific project/job.
- C. Verify all the documents including shop drawing and installation guidelines.
- D. Verify installation conditions are satisfactory to receive work of this section before the commencement
- E. Verify substrate installation is complete, flat, and true to plane.
- F. If substrate preparation is the responsibility of another installer, notify Architect of unsatisfactory preparation before proceeding.

3.3 Preparation:

- A. Field Measurements: Verify prior to fabrication and installation of the cladding panel.
- B. Protect surrounding areas and surfaces to preclude damage during work of this section.
- C. Lay out work before beginning installation as necessary for true, plumb and aligned panel installations.
- D. Verify locations of joints and panel lengths.

3.4 Installation:

- A. Conform to manufacturer's instructions and provisions of shop drawings.
- B. Install to allow hydro-thermal expansion/contraction.
- C. Use appropriate techniques/tools to work with the panel.
- D. Do not force to fit, do not bend, stretch/compress.
- E. Make cutting and fitting neat, square, and true. Where required cut, de-burr edges, and clean fillings from adjacent surfaces.
- F. Do not install damaged or questionable panels.
- G. Install solid phenolic wall panels plumb and level and accurately spaced.
- H. Anchor panels and other components of the work securely in place, with provisions for thermal and structural movement.
- I. Shim or otherwise plumb substrates receiving composite wall panels.
- J. Do not use construction adhesives to apply wall panels directly to substrates or wall board. Use mechanical fasteners only.

3.5 Erection Tolerances:

- A. Shim and align composite wall panel units within installed tolerance of 1/4 inch in 20 feet, non-accumulative, on level, plumb, and location lines as indicated and within 1/8 inch offset of adjoining faces and of alignment of matching profiles.

3.6 Field Quality Control:

- A. Manufacturer's Field Service: Provide field services to ensure product installation is in accordance with manufacturer's/fabricator's/supplier's instructions and installation manual, shop drawings etc.

3.7 Adjusting:

- A. Correct identified defects and irregularities.
- B. Replace damaged soiled, and discolored work.

3.8 Cleaning:

- A. Leave installation clean and free from residue and debris from work of this Section.
- B. Panels best cleaned with warm soapy water and rinsed with clear water; allowed to dry fully.

SECTION 09900 - PAINTS AND COATINGS

1.1 General: Provide paints and coatings as shown and specified.

- A. Provide surface preparation, prime, intermediate and finish coatings for interior and exterior and existing scheduled surfaces and items.
- B. Provide Tenant-selected finishes and colors for all exposed surfaces, unless otherwise indicated.

1.2 Related Documents:

- A. Drawings and general provisions of the Contract, including General and Supplementary Conditions and Division 1 Specification Sections, apply to this section.

1.3 Summary:

- A. This section includes surface preparation and field painting of the following:
1. Exposed exterior items and surfaces.
 2. Exposed interior items and surfaces.
 3. Surface preparation, priming, and finish coats specified in this Section are in addition to shop priming and surface treatment specified in other Sections.

1.4 Quality Assurance:

- A. Applicator Qualifications: Engage an experienced applicator that has completed painting system applications similar in material and extent to that indicated for this Project with a record of successful in-service performance.

- B. Source Limitations: Obtain block fillers, primers and undercoat materials for each coating system from the same manufacturer as the finish coats.

- C. Provide lead free prime and finish coatings. All top coatings shall be mold and mildew resistant.

1.5 Delivery, Storage and Handling:

- A. Deliver materials to the Project Site in manufacturer's original, unopened packages and containers bearing manufacturer's name and label, and the following information:
1. Product name or tile of material.
 2. Product description (generic classification or binder type).
 3. Manufacturer's stock number and date of manufacture.
 4. Contents by volume, for pigment and vehicle constituents.
 5. Thinning instructions.
 6. Application instructions.
 7. Color name and number.
 8. VOC content
- B. Store materials not in use in tightly covered containers in a well-ventilated area at a minimum ambient temperature of 45 degrees F (7 degrees C). Maintain containers used in storage in a clean condition, free of foreign materials and residue.
1. Protect from freezing. Keep storage area neat and orderly. Remove oily rags and waste daily. Take necessary measures to ensure that workers and work areas are protected from fire and health hazards resulting from handling, mixing and application.

1.6 Project Conditions

- A. Apply water-based paints only when the temperatures of surfaces to be painted and surrounding air temperatures are between 50 and 90 degrees F (10 and 32 degrees C) unless otherwise stated on the technical data bulletin.
- B. Apply solvent-thinned paints only when the temperature of surfaces to be painted and surrounding air temperatures are between 45 and 95 degrees F (7.2 and 35 degrees C).
- C. Do not apply paint in snow, rain, fog, or mist, or when the relative humidity exceeds 85 percent, or at temperatures less than 5 degrees F (3 degrees C) above the dew point, or to damp or wet surfaces.
1. Painting may continue during inclement weather if surfaces and areas to be painted are enclosed and heated within temperature limits specified by manufacturer during application and drying periods.

2.1 Manufacturers:

- A. Products: Subject to compliance with requirements, provide one of the products in the paint schedules.
- B. Manufacturers Names: The following manufacturer is referred to in the paint schedule by use of shortened versions of the name, which is shown below:
1. PPG Industries, Inc.
 2. Materials - No substitutions allowed.

2.2 Paint Materials, General

- A. Material Compatibility: Provide block fillers, primers, undercoats, and finish-coat materials that are compatible with one another and the substrates indicated under conditions of service and application, as demonstrated by manufacturer based on testing and field experience.
- B. Material Quality: Provide manufacturer's best-quality "professional" paint material of the various coating types specified. Paint-material containers not displaying manufacturer's product identification will not be acceptable.

Colors: Color guided selected by owner and will be strictly adhered too, unless otherwise noted.

C. Exterior Coatings:

Exterior Ferrous Metals:

Preparation: Remove all visible oil, grease, soil, rust and all other soluble contaminates from steel surface. Uniformly roughen surface with 150-grit paper. Remove all dust before solvent cleaning by the use of stiff bristle brush.

Prime: (1) Coat PPG: 4020PF Series Pitt-Tech Plus Int/Ext DTM Acrylic Industrial Primer (90 g/L VOC): Applied at a dry film thickness of not less than 2.0 to 4.0 mils.

Finish: (2) coats PPG: 4216 Plus HP Series Pitt-Tech Plus Semi-Gloss DTM Industrial Enamels (90 g/L VOC): Applied at a dry film thickness of not less than 2.0 to 4.0 mils.

Application: Conventional or HVLP (high volume low pressure)

Exterior and Interior Gas Piping:

Preparation: Remove all visible oil, grease, soil, rust and all other soluble contaminates from pipe surface. Remove all dust before solvent cleaning by the use of stiff bristle brush.

Prime: (1) Coat PPG: 4020PF Series Pitt-Tech Plus Int/Ext DTM Acrylic Industrial Primer (90 g/L VOC): Applied at a dry film thickness of not less than 2.0 to 4.0 mils.

Finish: (2) Coats PPG: 4216 Plus HP Series Pitt-Tech Plus Semi-Gloss DTM Industrial Enamels (90 g/L VOC): Applied at a dry film thickness of not less than 2.0 to 4.0 mils

Application: Conventional or HVLP (high volume low pressure)

Exterior Patio Railings:

Preparation: Remove all visible oil, grease, soil, loose paint, rust and all other soluble contaminates from steel surface. Remove all dust before solvent cleaning SSPC-SP1 by the use of stiff bristle brush. SSPC-SP3 may be required as a more aggressive preparation to remove loose mill scale, loose rust, loose paint and other loose detrimental foreign matter from the surface. Performance is better with more aggressive preparation.

Prime: (1) coat PPG: 95-3300 Durathane DTM Urethane Mastic (250 g/L VOC): Applied at a dry film thickness of not less than 3.0 to 5.0 mils.

Finish: (1) coat PPG: 95-3300 Durathane DTM Urethane Mastic (250 g/L VOC): Applied at a dry film thickness of not less than 3.0 to 5.0 mils.

Application: Conventional or HVLP (high volume low pressure) be done with conventional spray or airless equipment or brush or roller.

Exterior Prefinished Metal Wall Panels:

Preparation: Before applying primer or other surface treatments, clean galvanized metal surface to SSPC-SP1 that could impair bond of the various coatings. Remove oil, grease and soap film before priming use of Krud Kutter Metal Clean & Etch may be required on bare or new galvanized. Surface must be clean, dry and free of contaminants, including salt deposits. Additional prep may be needed to SSPC-SP2. Schedule cleaning and painting so dust and other contaminants from the cleaning process will not fall on wet, newly painted surfaces.

Note: Some selected areas of bare concrete surfaces will require (1) coat of Perma Crete 4-603XI Alkali Resistant Concrete Primer before steel installation over all concrete surfaces.

Owner Option 1:

Prime: (1) coat XIM Primer Bond - Applied at a dry film thickness of not less than 1.5 to 2.0 mils.

Finish: (2) coats PPG: 90-1110 Series Pitt-Tech Satin DTM Industrial Enamels (90 g/L VOC): Applied at a dry film thickness of not less than 2.0 to 4.0 mils.

Owner Option 2:

Prime: (1) coat PPG: 97-245 Pitt-Guard DTR Epoxy Mastic Primer (263 g/L VOC): Applied at a dry film thickness of not less than 4.0 to 7.0 mils.

Finish: (2) coats PPG: 95-3300 Durathane Urethane Mastic (240 g/L VOC): Applied at a dry film thickness of not less than 2.0 to 4.0 mils.

Owner Option 3 (Low VOC):

Prime: (1) coat PPG: Amerlock 2 Fast Dry VOC Compliant Epoxy (84 g/L VOC): Applied at a dry film thickness of not less than 4.0 to 6.0 mils.

Finish: (2) coats PPG: Amershield VOC Aliphatic Urethane (84 g/L VOC): Applied at a dry film thickness of not less than 5.0 to 8.0 mils.

Application: Conventional or HVLP (high volume low pressure) be done with conventional spray or airless equipment or brush or roller.

Exterior Galvanized Metal:

Preparation: Before applying primer or other surface treatments, clean galvanized metal surface to SSPC-SP1 that could impair bond of the various coatings. Remove oil, grease and soap film before priming use of Krud Kutter Metal Clean & Etch may be required on bare or new galvanized. Surface must be clean, dry and free of contaminants, including salt deposits. Additional prep may be needed to SSPC-SP2. Schedule cleaning and painting so dust and other contaminants from the cleaning process will not fall on wet, newly painted surfaces.

Note: Some selected areas of bare concrete surfaces will require (1) coat of Perma Crete 4-503 Concrete Primer before steel installation over all concrete surfaces.

Owner Option 1:

Prime: (1) coat PPG: 6-209 SpeedHide Galvanized Metal Primer (400 g/L VOC): Applied at a dry film thickness of not less than 3.0 to 5.0 mils.

Finish: (2) coats PPG: 4216 Plus HP Series Pitt-Tech Plus Semi-Gloss DTM Industrial Enamels (90 g/L VOC): Applied at a dry film thickness of not less than 2.0 to 4.0 mils.

Owner Option 2:

Prime: (1) coat PPG: 97-245 Pitt-Guard DTR Epoxy Mastic Primer (263 g/L VOC): Applied at a dry film thickness of not less than 4.0 to 7.0 mils.

Finish: (2) coats PPG: 95-3300 Durathane Urethane Mastic (240 g/L VOC): Applied at a dry film thickness of not less than 2.0 to 4.0 mils.

Owner Option 3 (Low VOC):

Prime: (1) coat PPG: Amerlock 2 Fast Dry VOC Compliant Epoxy (84 g/L VOC): Applied at a dry film thickness of not less than 4.0 to 6.0 mils.

Finish: (2) coats PPG: Amershield VOC Aliphatic Urethane (84 g/L VOC): Applied at a dry film thickness of not less than 5.0 to 8.0 mils.

Application: Conventional or HVLP (high volume low pressure) be done with conventional spray or airless equipment or brush or roller.



CLIENT:




CHIPOTLE MEXICAN GRILL, INC.
PO BOX 182966
COLUMBUS, OH 43218-2566
TELEPHONE: (614) 318-2682
INTERNET: WWW.CHIPOTLE.COM

COPYRIGHT 2024
THIS DRAWING IS AN INSTRUMENT OF SERVICE AND AS SUCH REMAINS THE PROPERTY OF CHIPOTLE MEXICAN GRILL, INC. PERMISSION FOR USE OF THIS DOCUMENT IS LIMITED AND CAN BE EXTENDED ONLY BY WRITTEN AGREEMENT WITH CHIPOTLE MEXICAN GRILL, INC.

PROJECT INFORMATION:

STORE NO.: 4757
"ANDERSON IN"
S SCATTERFIELD RD & 59TH STREET
ANDERSON, IN 46013

SEAL:

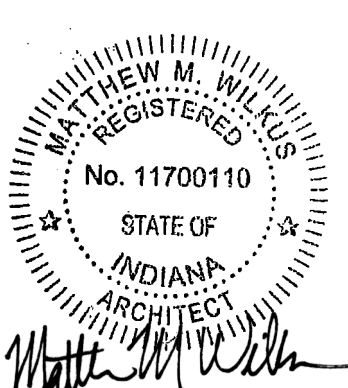

July 25, 2024

MATTHEW M. WILKUS
LICENSE #A11700110
(EXPIRES 12/31/2024)

PROJECT NO. 2022-0494

DRAWN BY RDB

CHECKED BY

ISSUE RECORD:

12/12/2023	PERMIT SET
06/19/2024	BID SET
07/24/2024	CONSTRUCTION SET


REVISIONS:

TITLE:


ARCHITECTURAL
SPECIFICATIONS

SHEET NUMBER:

G016

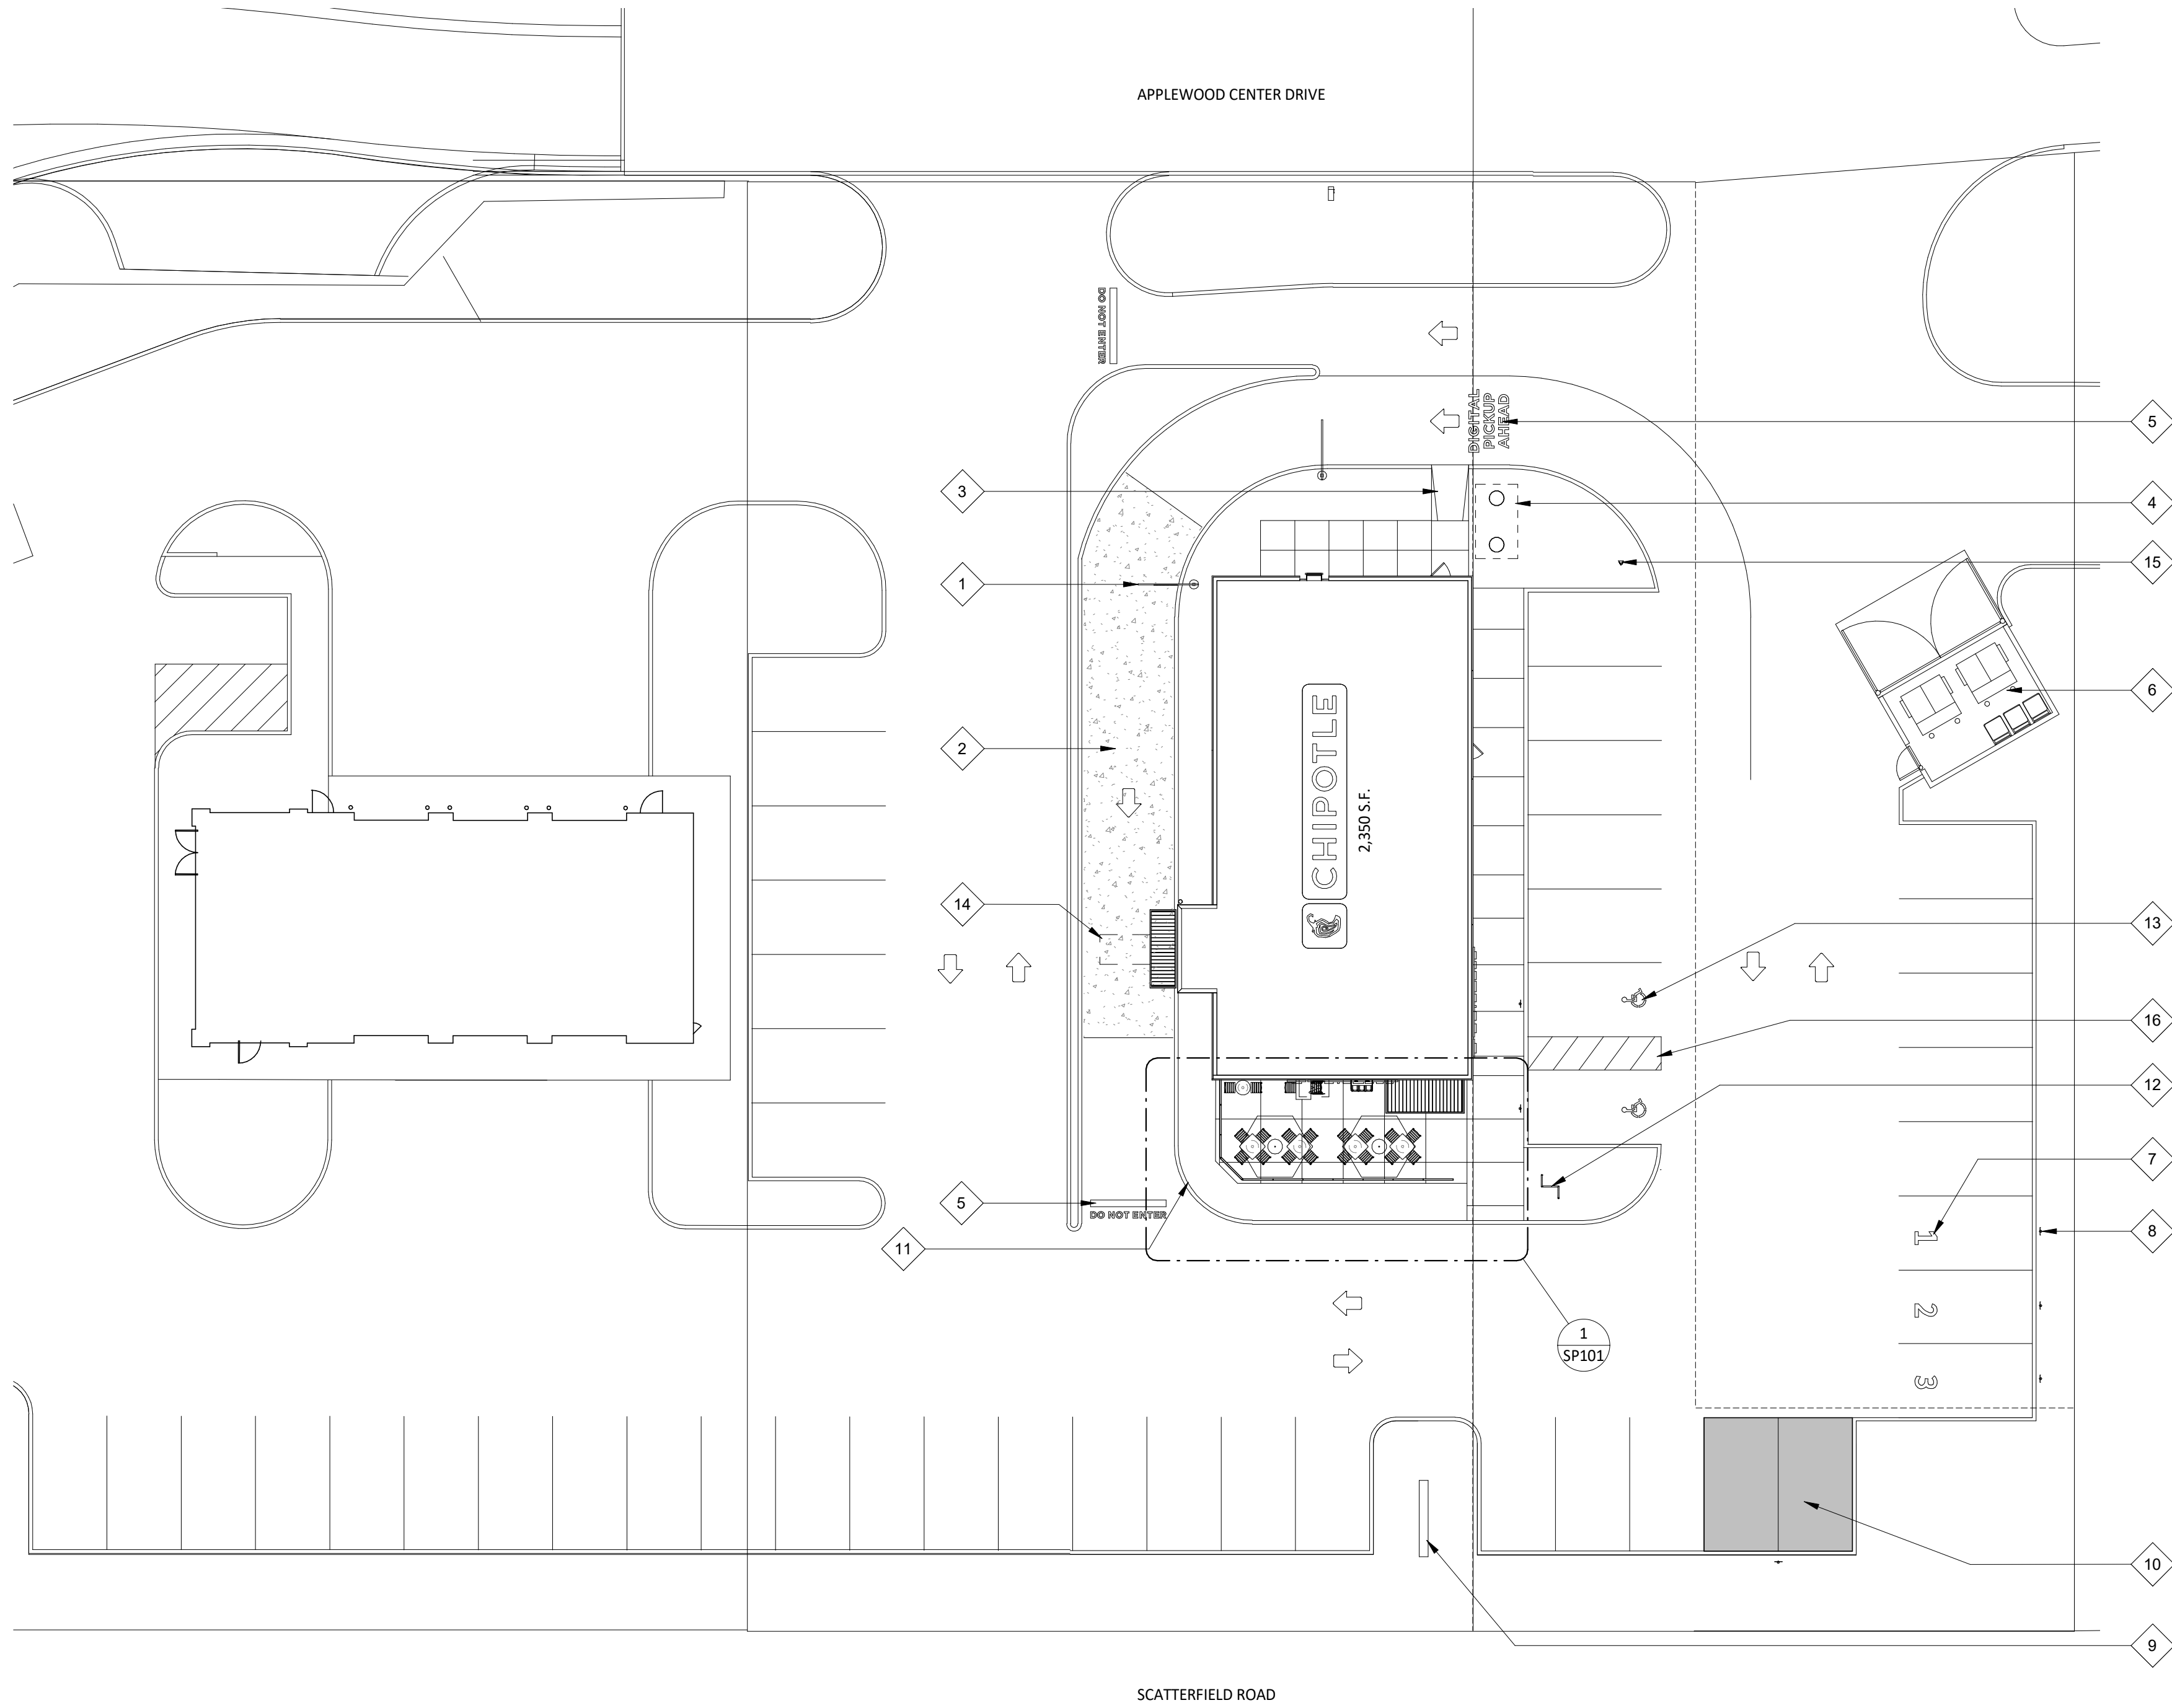

 1 ARCHITECTURAL SITE PLAN
SCALE: 1/16" = 1'-0"



GENERAL NOTES - SITE PLAN

1. ALL SITE WORK INCLUDING PAVING, CURBING, PARKING, PARKING LOT LIGHTING, SIDEWALKS, LANDSCAPING, AND DUMPSTER ENCLOSURE ARE EXISTING UNLESS NOTED OTHERWISE.
2. FOR STENCIL INFORMATION, REFER TO DIVISION 2 - SITE CONSTRUCTION FOR ADDITIONAL INFORMATION.
3. PROVIDED ARCHITECTURAL SITE PLAN IS FOR REFERENCE PURPOSES ONLY. GENERAL CONTRACTOR TO VERIFY LANDLORD PROVIDED ITEMS MATCH THE INDICATED NOTING BELOW AS REQUIRED. IF GENERAL CONTRACTOR ENCOUNTERS ANY DISCREPANCIES, CONTACT THE ARCHITECT IMMEDIATELY.

KEYNOTE LEGEND

- | | |
|----|--|
| 1 | CLEARANCE BAR AND FOUNDATION SUPPLIED AND INSTALLED BY TSV - REFER TO SP101 FOR ADDITIONAL INFORMATION. |
| 2 | 12' - 0" WIDE X 44' - 0" LONG CONCRETE DRIVE AISLE - EXTEND TO 12' - 0" LINEAL FEET BEYOND THE CENTERLINE OF THE PICK-UP WINDOW, EXTEND 12'-0" BEFORE CLEARANCE BAR |
| 3 | CURB RAMP FOR DELIVERIES, BY LANDLORD. |
| 4 | 1,500 GALLON GREASE INTERCEPTOR LOCATION - CHIPOTLE'S GENERAL CONTRACTOR TO REFER TO PLUMBING DRAWINGS FOR ADDITIONAL INFORMATION. |
| 5 | "DO NOT ENTER" AND "DIGITAL PICKUP AHEAD" AND DIRECTIONAL ARROWS PROVIDED BY LANDLORD. |
| 6 | TRASH ENCLOSURE, PAD, APRON AND BOLLARD LOCATION BY LANDLORD. |
| 7 | THREE (3) PULL-AHEAD PARKING SPACES MARKED WITH WHITE NUMBERS PARALLEL TO STRIPING AND CENTERED IN SPACE - OFFSET NUMBERS INTO PARKING SPACE 12" MAX. FROM FRONT EDGE OF STRIPING. |
| 8 | THREE (3) POLE SIGNS FOR PULL-AHEAD PARKING SPACES - FOUNDATION AND POLE BY GENERAL CONTRACTOR - SIGN PROVIDED BY TSV - INSTALLED BY GENERAL CONTRACTOR. |
| 9 | MONUMENT SIGNAGE BASE LOCATION PROVIDED BY LANDLORD - SIGN CABINET AND POWER HOOK-UPS ARE TO BE PROVIDED BY TSV. |
| 10 | TWO (2) SPACES MARKED FOR 'BURRITO LOADING ZONE' PARKING - FOUNDATION AND POLE BY GENERAL CONTRACTOR - SIGN PROVIDED BY TSV - INSTALLED BY GENERAL CONTRACTOR. |
| 11 | CONCRETE PATIO SLAB BY LANDLORD. |
| 12 | GROUND MOUNTED, GALVANIZED MADRAX 4-BIKE BIKE RACK - PROVIDED BY LANDLORD. |
| 13 | SHADED AREA INDICATES AREA NOT PART OF SCOPE. |
| 14 | LOOP DETECTOR INSTALLED BY CHIPOTLE'S GENERAL CONTRACTOR - REFER TO ELECTRICAL DRAWINGS FOR ADDITIONAL INFORMATION - EXISTING CONDUIT STUB-UP PROVIDED BY LANDLORD. |
| 15 | FOUNDATION FOR "DIGITAL PICK-UP" SIGNAGE TO BE PROVIDED BY LANDLORD - "DIGITAL PICK-UP" SIGNAGE SUPPLIED AND INSTALLED BY TSV - REFER TO SP101 FOR ADDITIONAL INFORMATION. |
| 16 | SHARED CURB RAMP FOR ACCESSIBLE PARKING AND TRASH, BY LANDLORD |



CLIENT:




CHIPOTLE MEXICAN GRILL, INC.
PO BOX 18296
COLUMBUS, OH 43218-2968
TELEPHONE: (614) 318-2682
INTERNET: WWW.CHIPOTLE.COM

COPYRIGHT 2024
THIS DRAWING IS AN INSTRUMENT OF SERVICE AND AS SUCH REMAINS THE PROPERTY OF CHIPOTLE MEXICAN GRILL, INC. PERMISSION FOR USE OF THIS DOCUMENT IS LIMITED AND CAN BE EXTENDED ONLY BY WRITTEN AGREEMENT WITH CHIPOTLE MEXICAN GRILL, INC.

PROJECT INFORMATION:

STORE NO.: 4757
"ANDERSON IN"
S SCATTERFIELD RD & 59TH STREET
ANDERSON, IN 46013

SEAL:

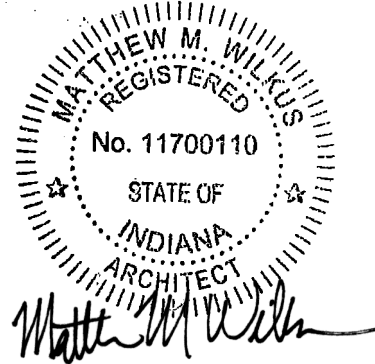

JULY 25, 2024
MATTHEW M. WILKUS
LICENSE #AR11700110
(EXPIRES 12/31/2024)

PROJECT NO. 2022-0494
DRAWN BY RDB
CHECKED BY

ISSUE RECORD:
12/12/2023 PERMIT SET
06/19/2024 BID SET
07/24/2024 CONSTRUCTION SET

REVISIONS:

TITLE:


SITE PLAN

SHEET NUMBER:

SP100


1 SLAB WORK PLAN

SCALE: 1/4" = 1'-0"

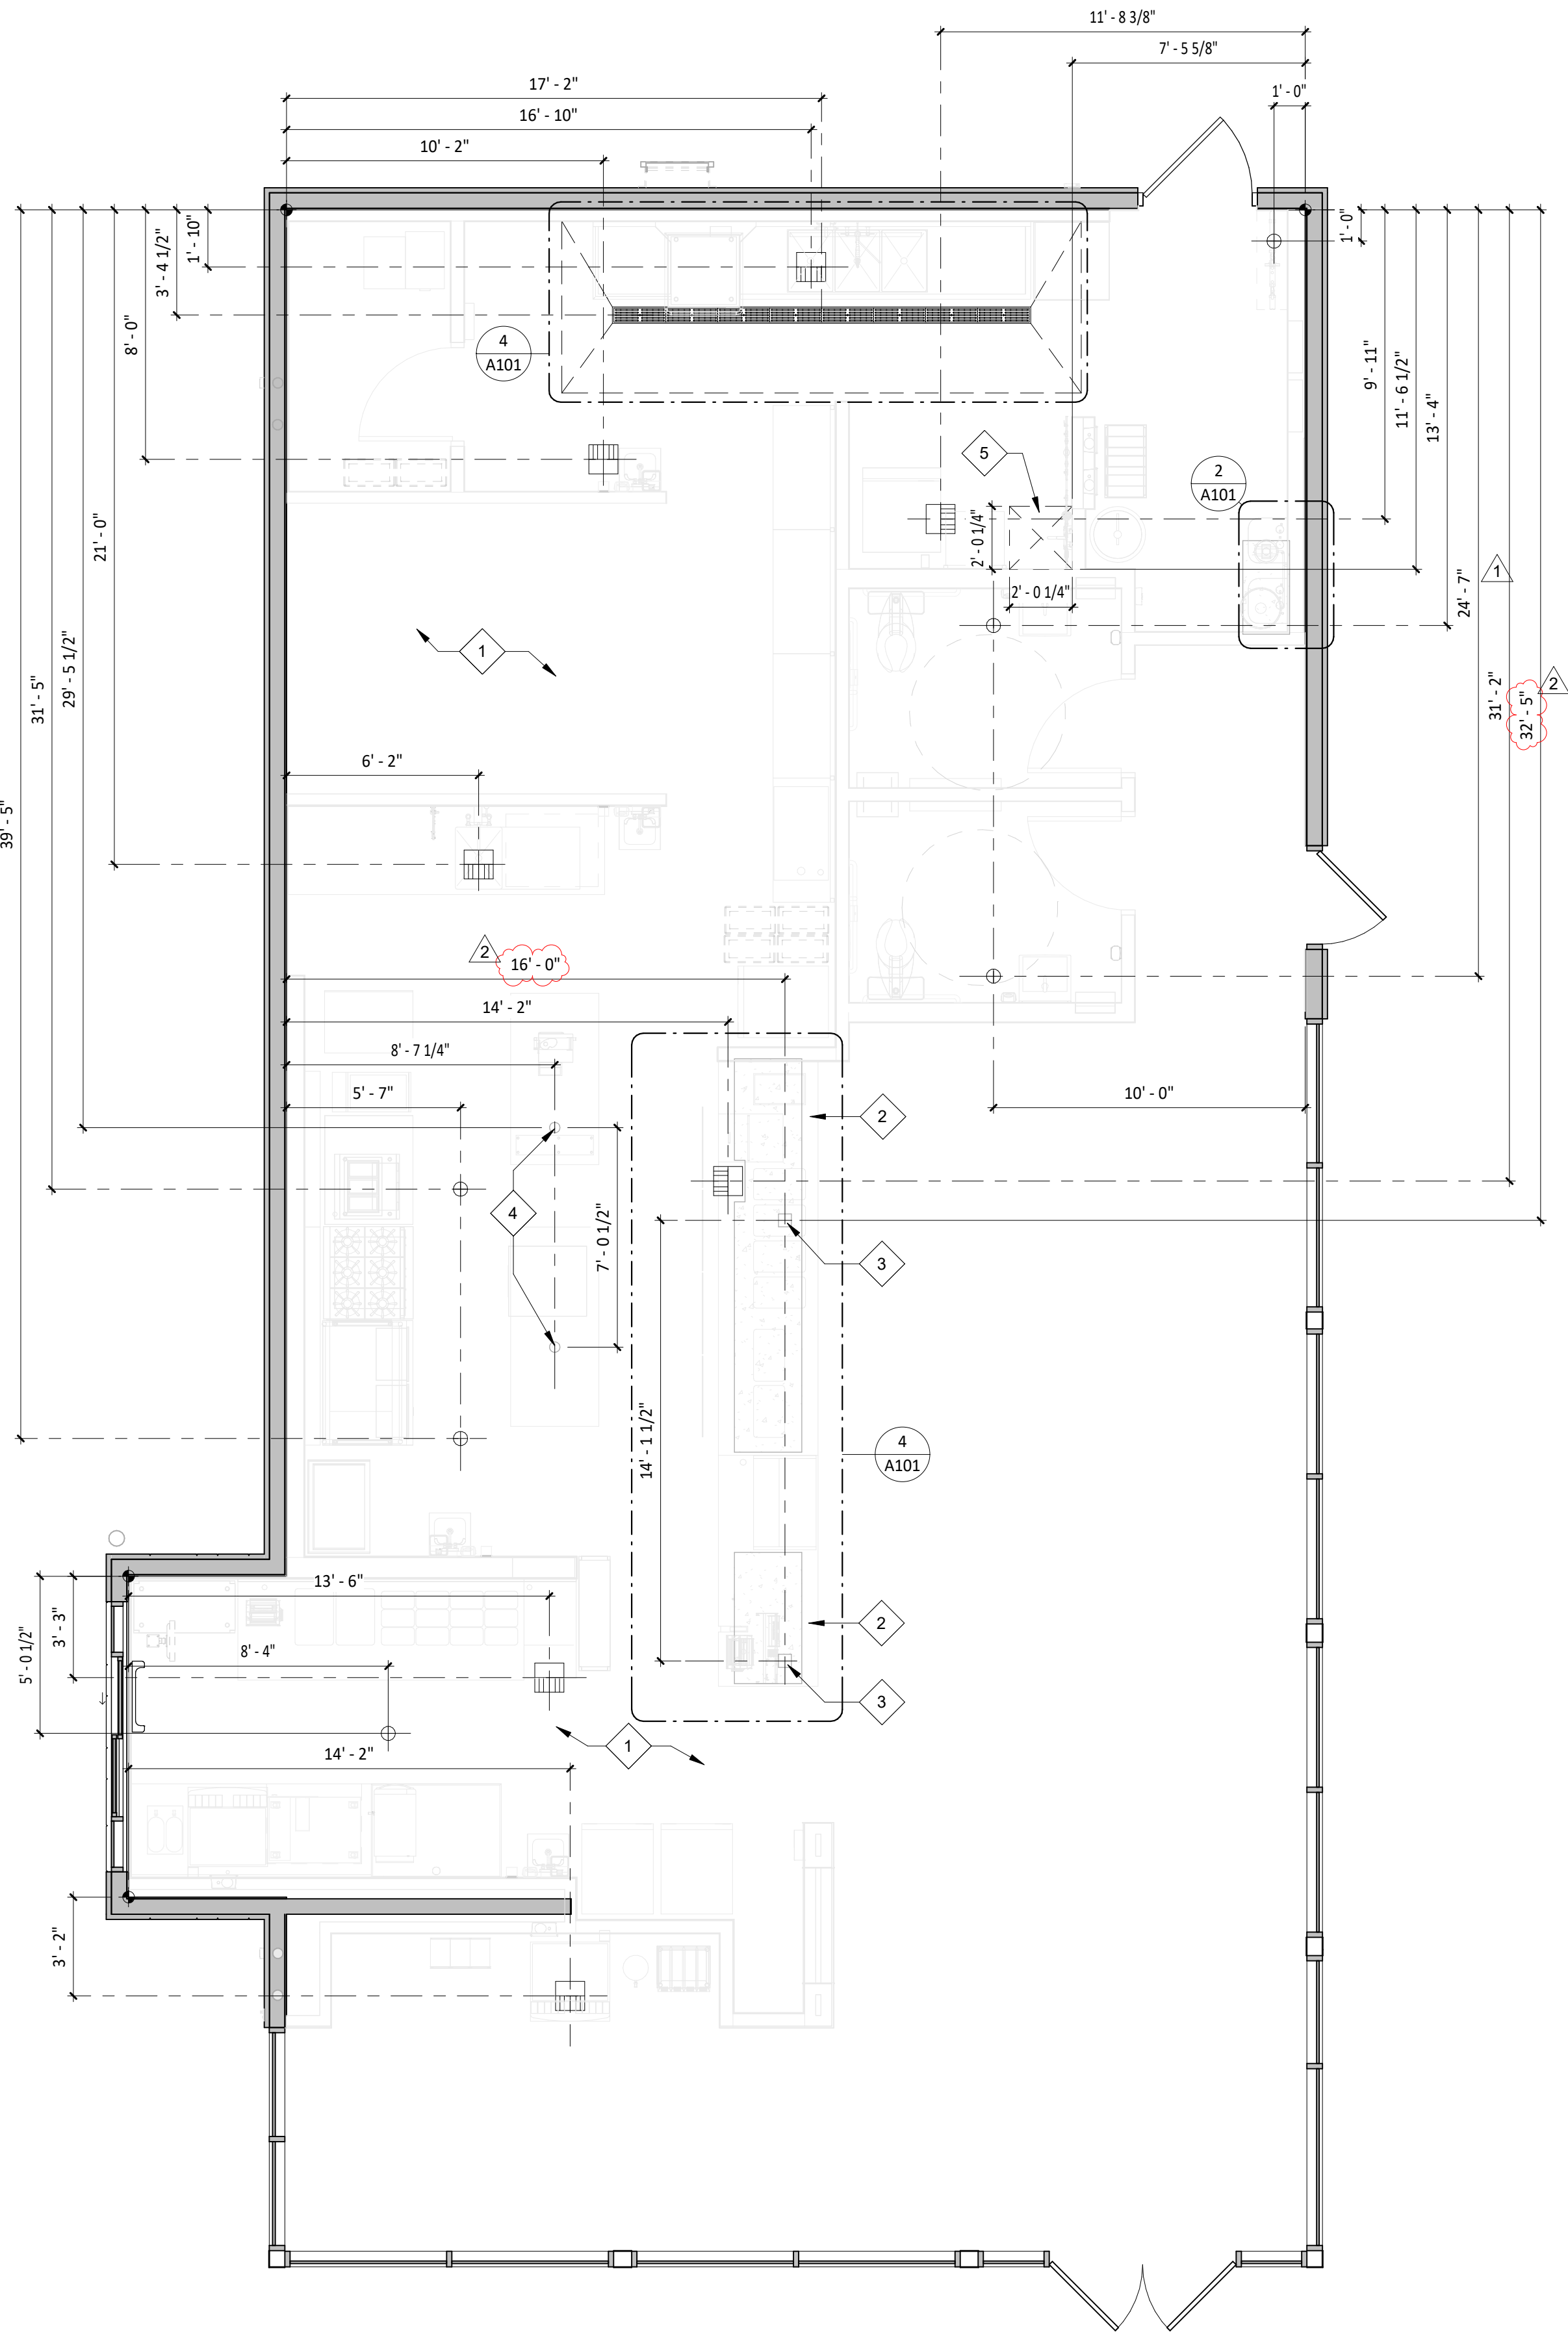


2 CURB PLAN @ SOFTNER

SCALE: 1/2" = 1'-0"

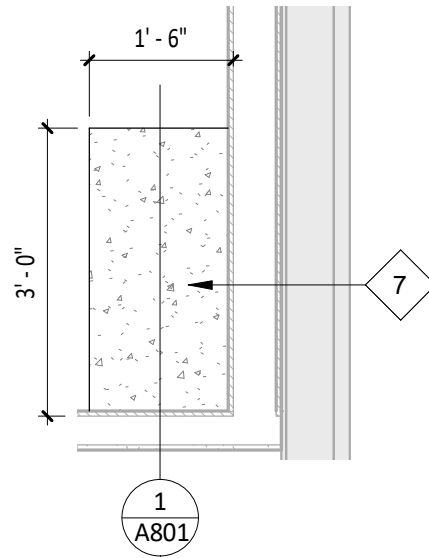


3 CURB PLAN

SCALE: 1/4" = 1'-0"

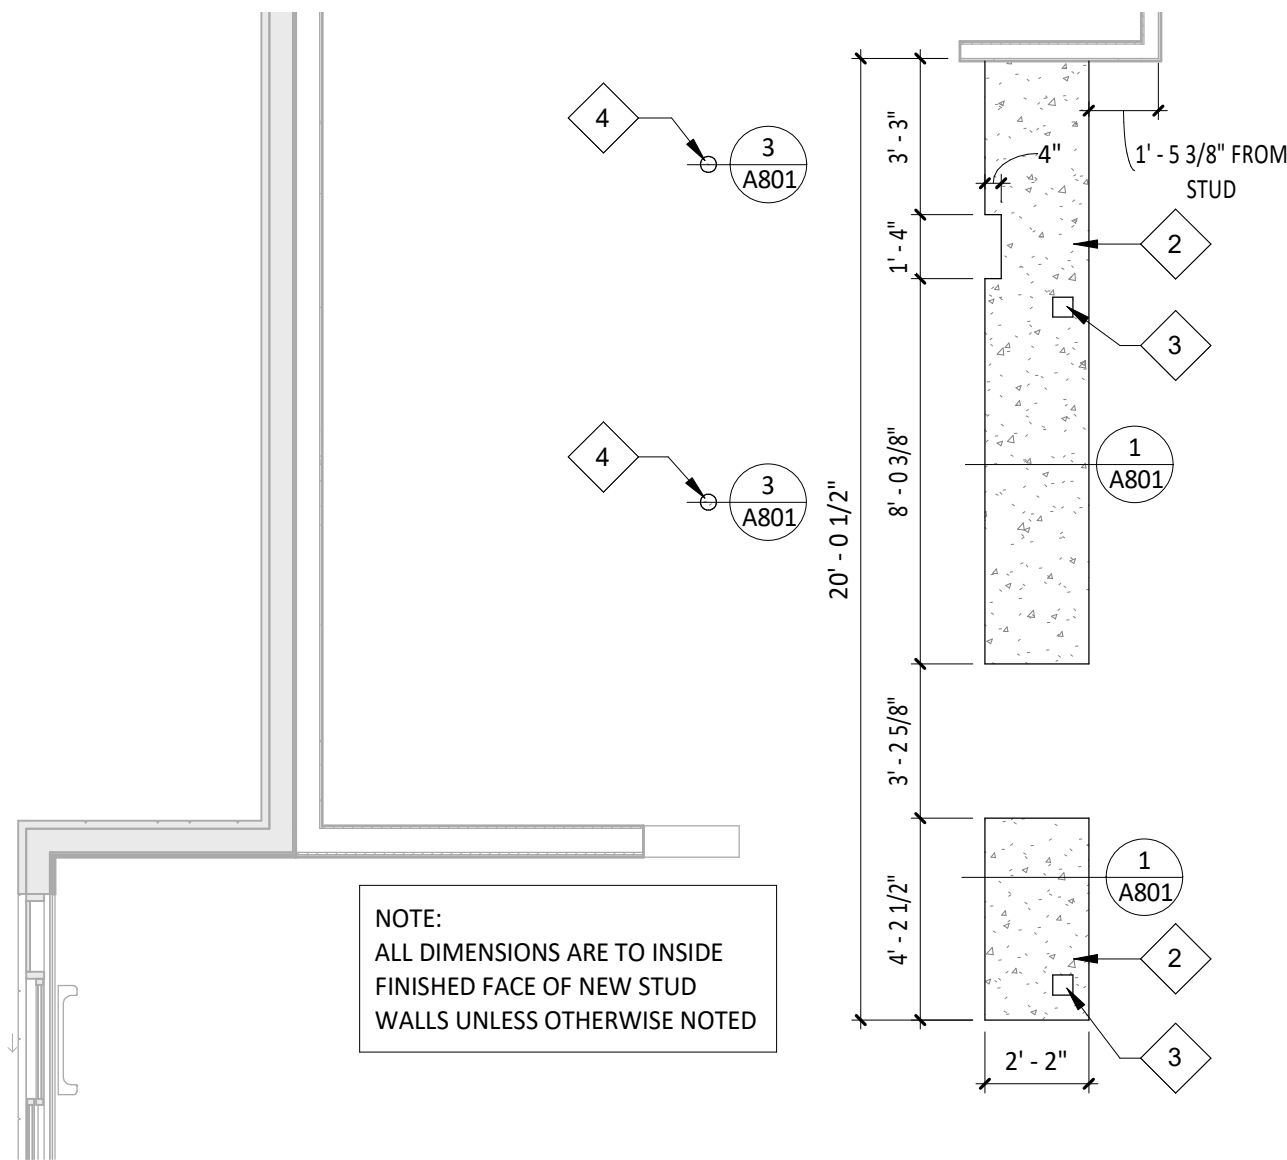

4 TRENCH DRAIN DETAIL

SCALE: 1/2" = 1'-0"

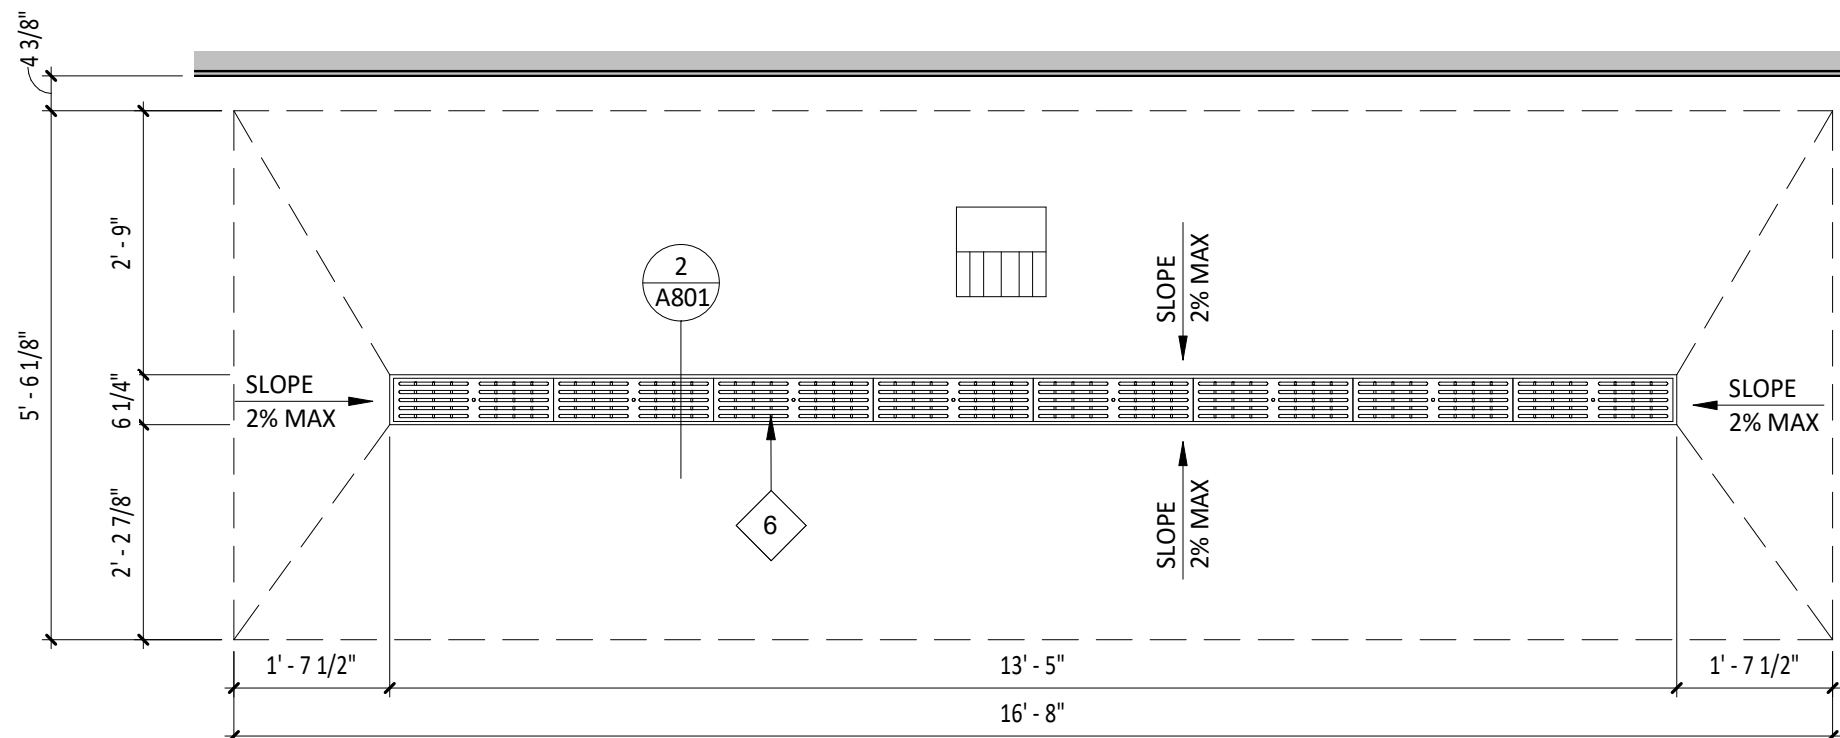

GENERAL NOTES - SLAB PLAN

- ALL DIMENSIONS ARE TO THE INSIDE FINISHED FACE OF EXISTING GYP. BD. UNLESS NOTED OTHERWISE.
- ALL DIMENSIONS ARE TO THE CENTERLINE OF FIXTURE UNLESS NOTED OTHERWISE.
- GC TO REVIEW ELECTRICAL PLANS FOR LIGHTING OR POWER STUB LOCATIONS PRIOR TO POURING SLAB.
- REFER TO "03300 - CAST-IN-PLACE CONCRETE" IN SPECIFICATIONS FOR CONCRETE PATCHING OR INSTALLATION INFORMATION.
- VERIFY PERIMETER FOUNDATION INSULATION IS EXISTING IN FIELD AND NOTIFY ARCHITECT OF ANY DISCREPANCIES PRIOR TO COMMENCEMENT OF CONSTRUCTION.
- ALL TILED FLOOR TO MAINTAIN POSITIVE SLOPE TO ALL FLOOR DRAINS OF NOT GREATER THAN 2% SLOPE FOR A 4'X4' AREA U.N.O.
- EXISTING SLAB TO BE TRENCHED AS NEEDED PER PLUMBING AND ARCHITECTURAL PLANS.
- COORDINATE SYRUP LINE ROUTING WITH EXISTING UNDER SLAB CONDITIONS WHEN PLANS INDICATE UNDERSLAB SYRUP LINES.

PLUMBING LEGEND

- FLOOR SINK LOCATION FLOOR DRAIN LOCATION

KEYNOTE LEGEND

- LANDLORD TO PROVIDE POROUS FILL - CHIPOTLE GENERAL CONTRACTOR TO PROVIDE 10 MIL VAPOR BARRIER AND 4" MINIMUM CONCRETE SLAB ON GRADE - REFER TO STRUCTURAL DRAWINGS FOR ADDITIONAL INFORMATION.
- 4" CONCRETE CURB - COORDINATE EXACT LOCATION WITH FINAL EQUIPMENT LOCATIONS - SEE DETAILS 1/A801 FOR ADDITIONAL INFORMATION.
- 5" X 5" POWER STUB LOCATION - COORDINATE WITH ELECTRICAL PLANS FOR ADDITIONAL INFORMATION.
- 4" PVC PIPE WITH 2" HIGH CONCRETE INFILL FOR POWER STUBS - TYPICAL OF TWO (2) - REFER TO ELECTRICAL DRAWINGS FOR ADDITIONAL INFORMATION.
- OUTLINE OF MOP SINK AS INDICATED.
- TRENCH DRAIN TO BE RECESSED INTO SLAB A MINIMUM OF 8" THICK CONCRETE SLAB WITH 4" MINIMUM CONCRETE BED BELOW - REFER TO MANUFACTURER'S INSTALLATION INSTRUCTIONS - SEE DETAIL 3/A101 FOR ADDITIONAL INFORMATION - SLOPE FLOOR IN THIS AREA ONLY TOWARDS DRAIN 1/40.
- 5" CONCRETE CURB - COORDINATE EXACT LOCATION WITH FINAL EQUIPMENT LOCATIONS - SEE DETAILS 1/A801 FOR ADDITIONAL INFORMATION.



CLIENT:



CHIPOTLE MEXICAN GRILL, INC.
PO BOX 18266
COLUMBUS, OH 43218-2666
TELEPHONE: (614) 315-2662
INTERNET: WWW.CHIPOTLE.COM

COPYRIGHT 2024
THIS DRAWING IS AN INSTRUMENT OF SERVICE AND AS SUCH REMAINS THE PROPERTY OF CHIPOTLE MEXICAN GRILL, INC. PERMISSION FOR USE OF THIS DOCUMENT IS LIMITED AND CAN BE EXTENDED ONLY BY WRITTEN AGREEMENT WITH CHIPOTLE MEXICAN GRILL, INC.

PROJECT INFORMATION:

STORE NO.: 4757
"ANDERSON IN"
S SCATTERFIELD RD & 59TH STREET
ANDERSON, IN 46013

SEAL:



July 25, 2024

MATTHEW M. WILKUS
LICENSE #AR11700110
(EXPIRES 12/31/2024)

PROJECT NO. 2022-0494

DRAWN BY RDB

CHECKED BY

ISSUE RECORD:

12/12/2023 PERMIT SET

06/19/2024 BID SET

07/24/2024 CONSTRUCTION SET

REVISIONS:

1 05/20/2024 DB UPDATES




2 07/24/2024 CONSTRUCTION SET

TITLE:

SLAB WORK PLAN

SHEET NUMBER:

A101

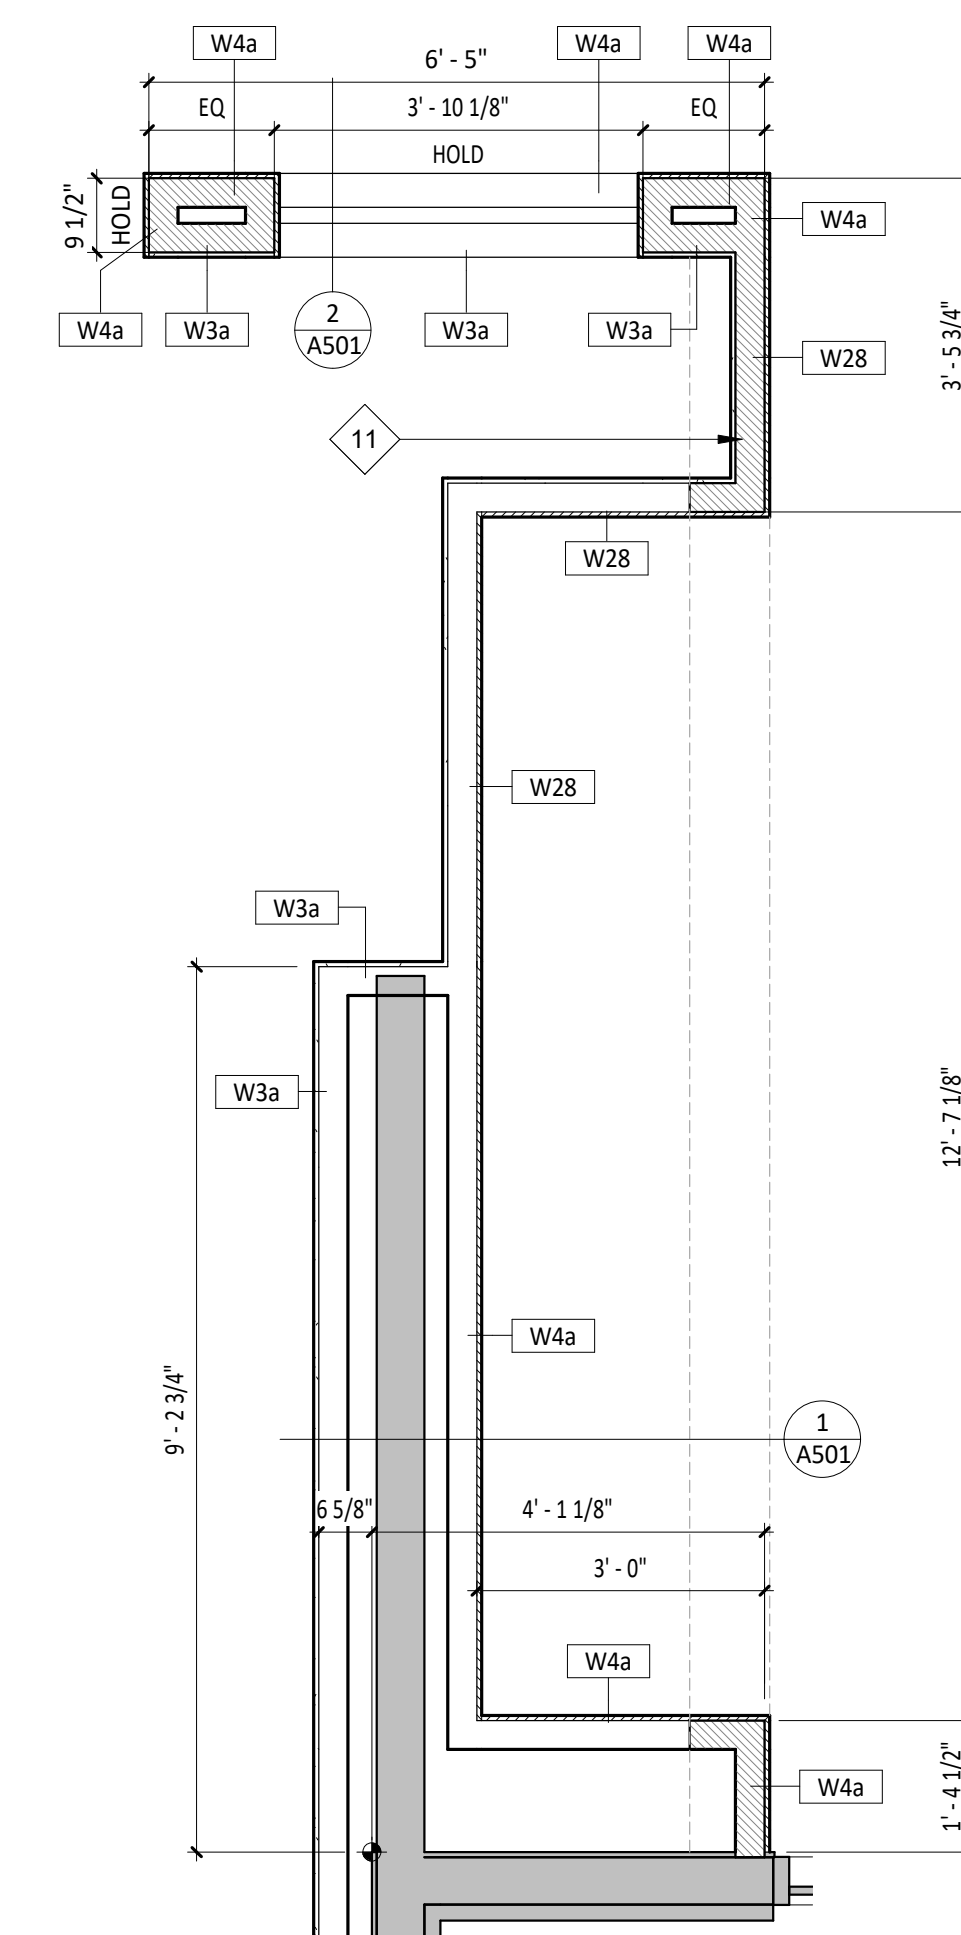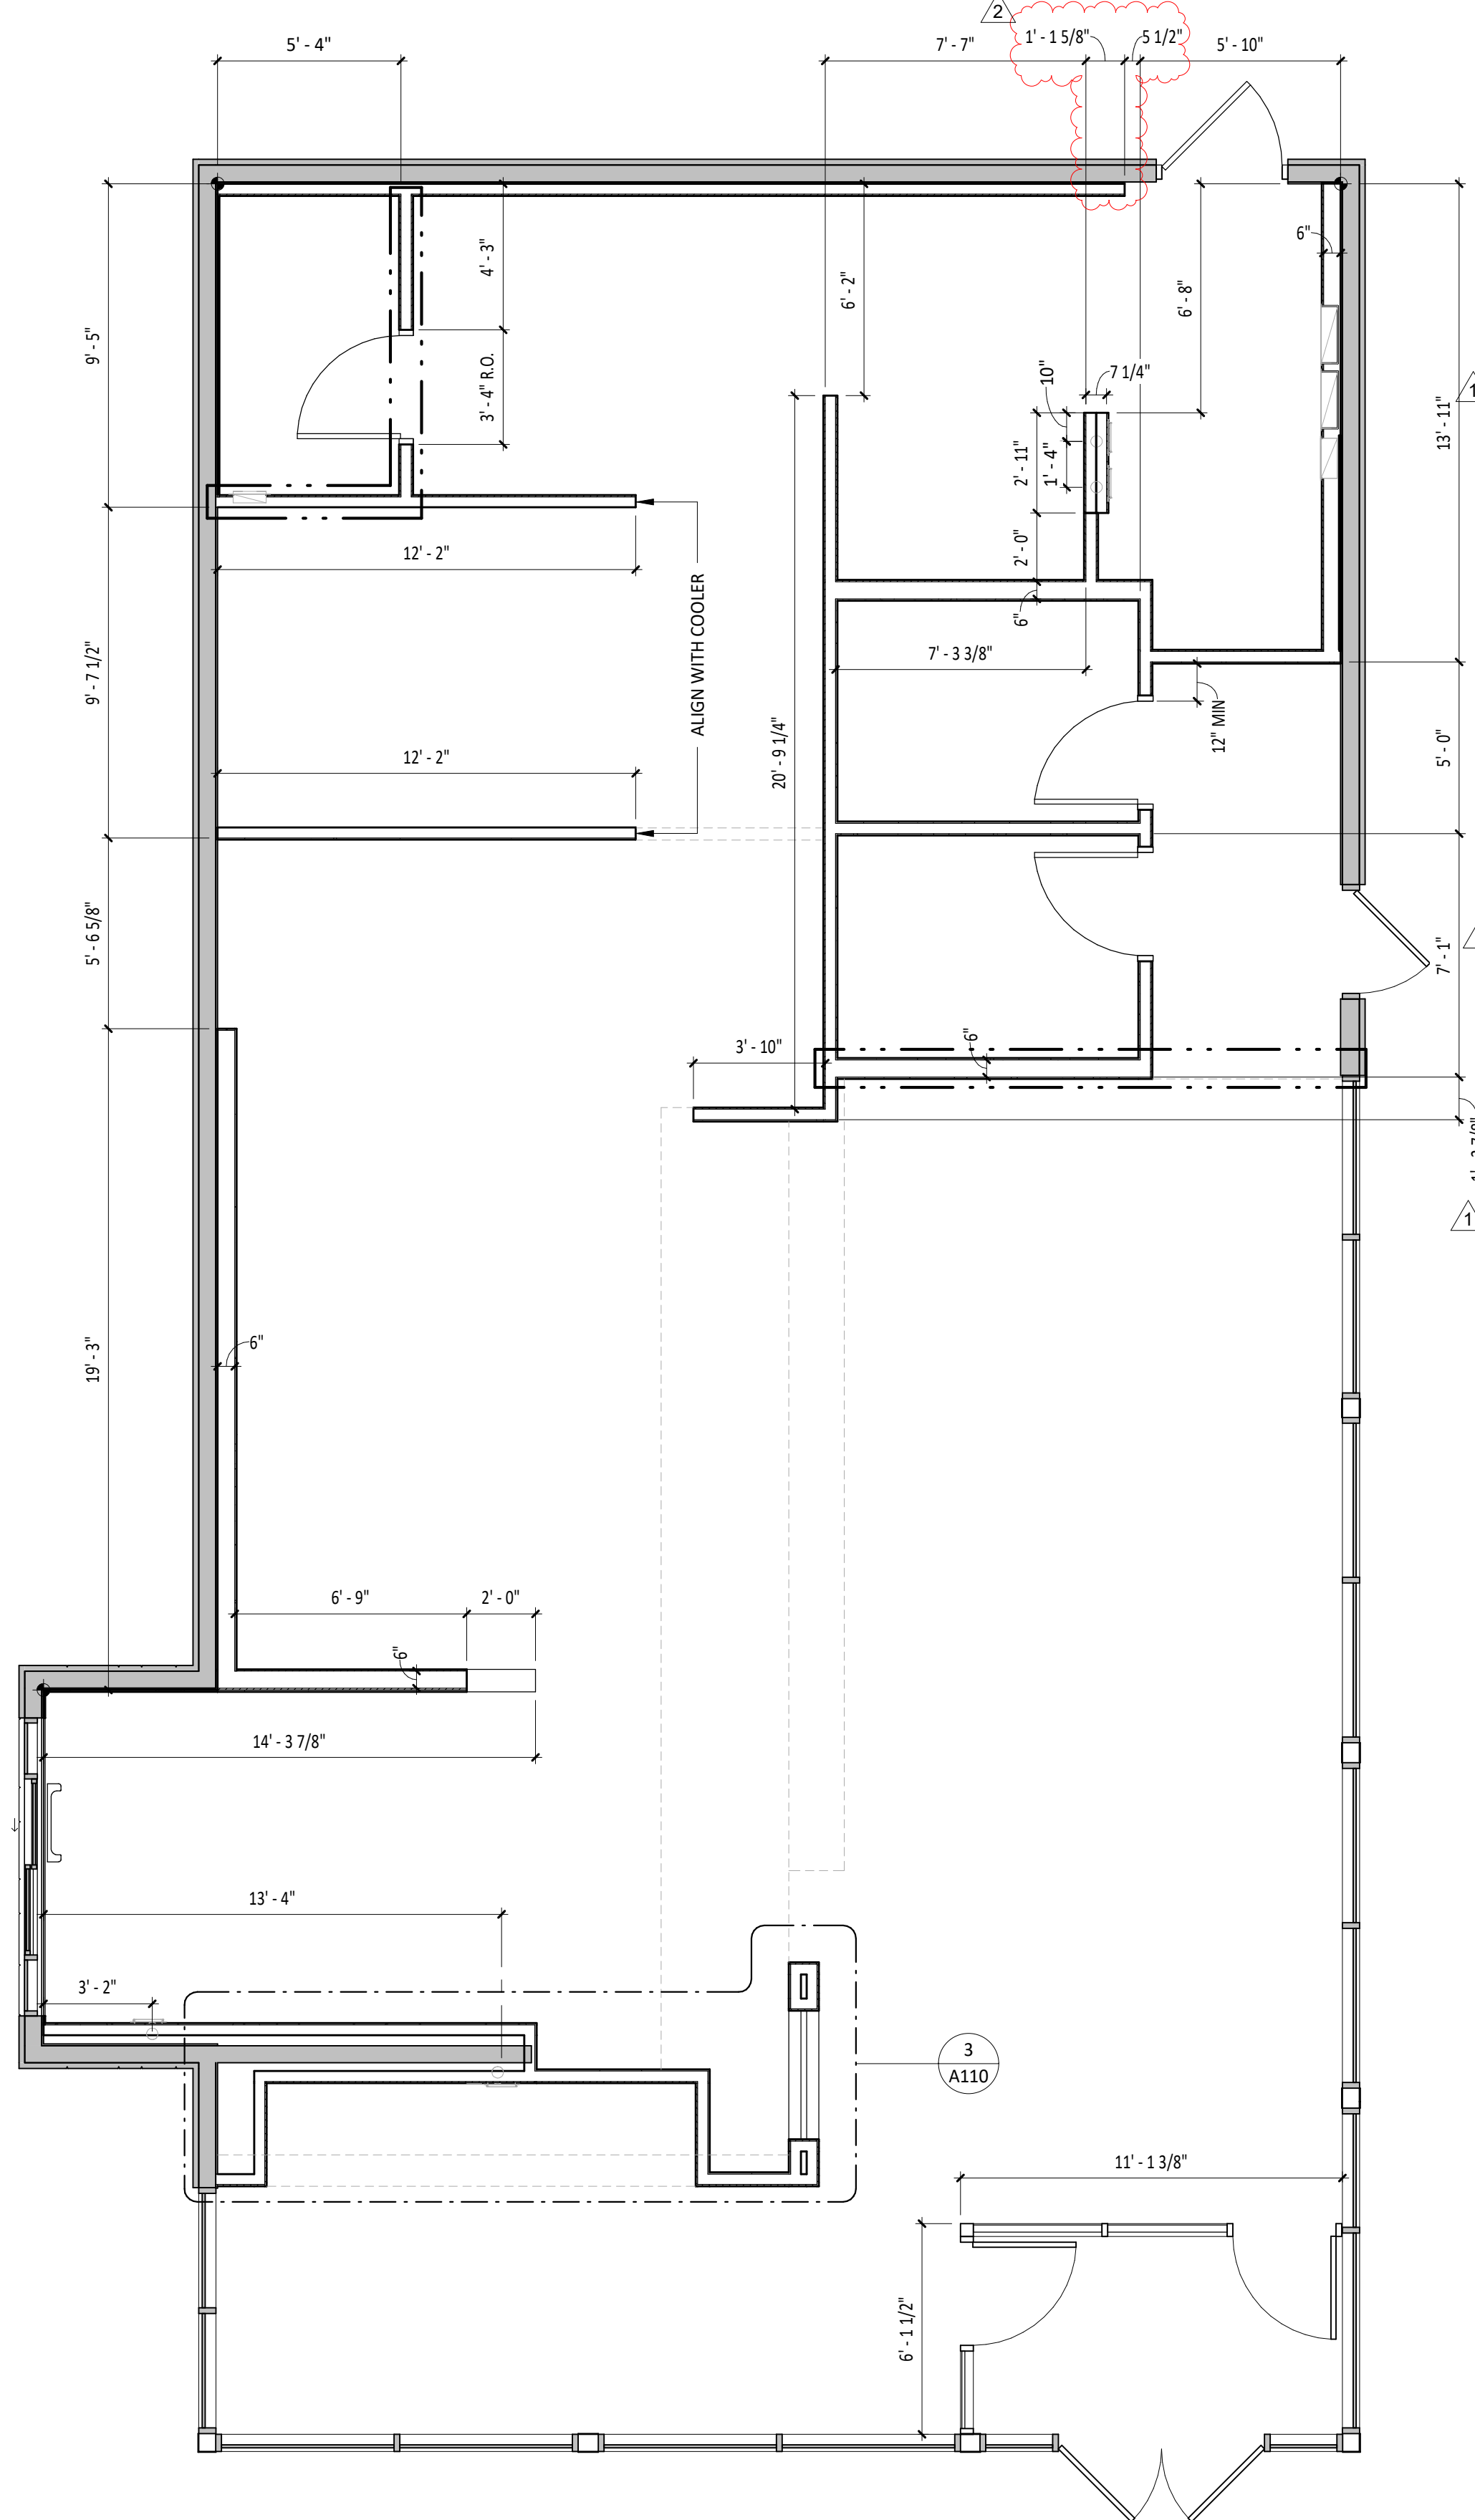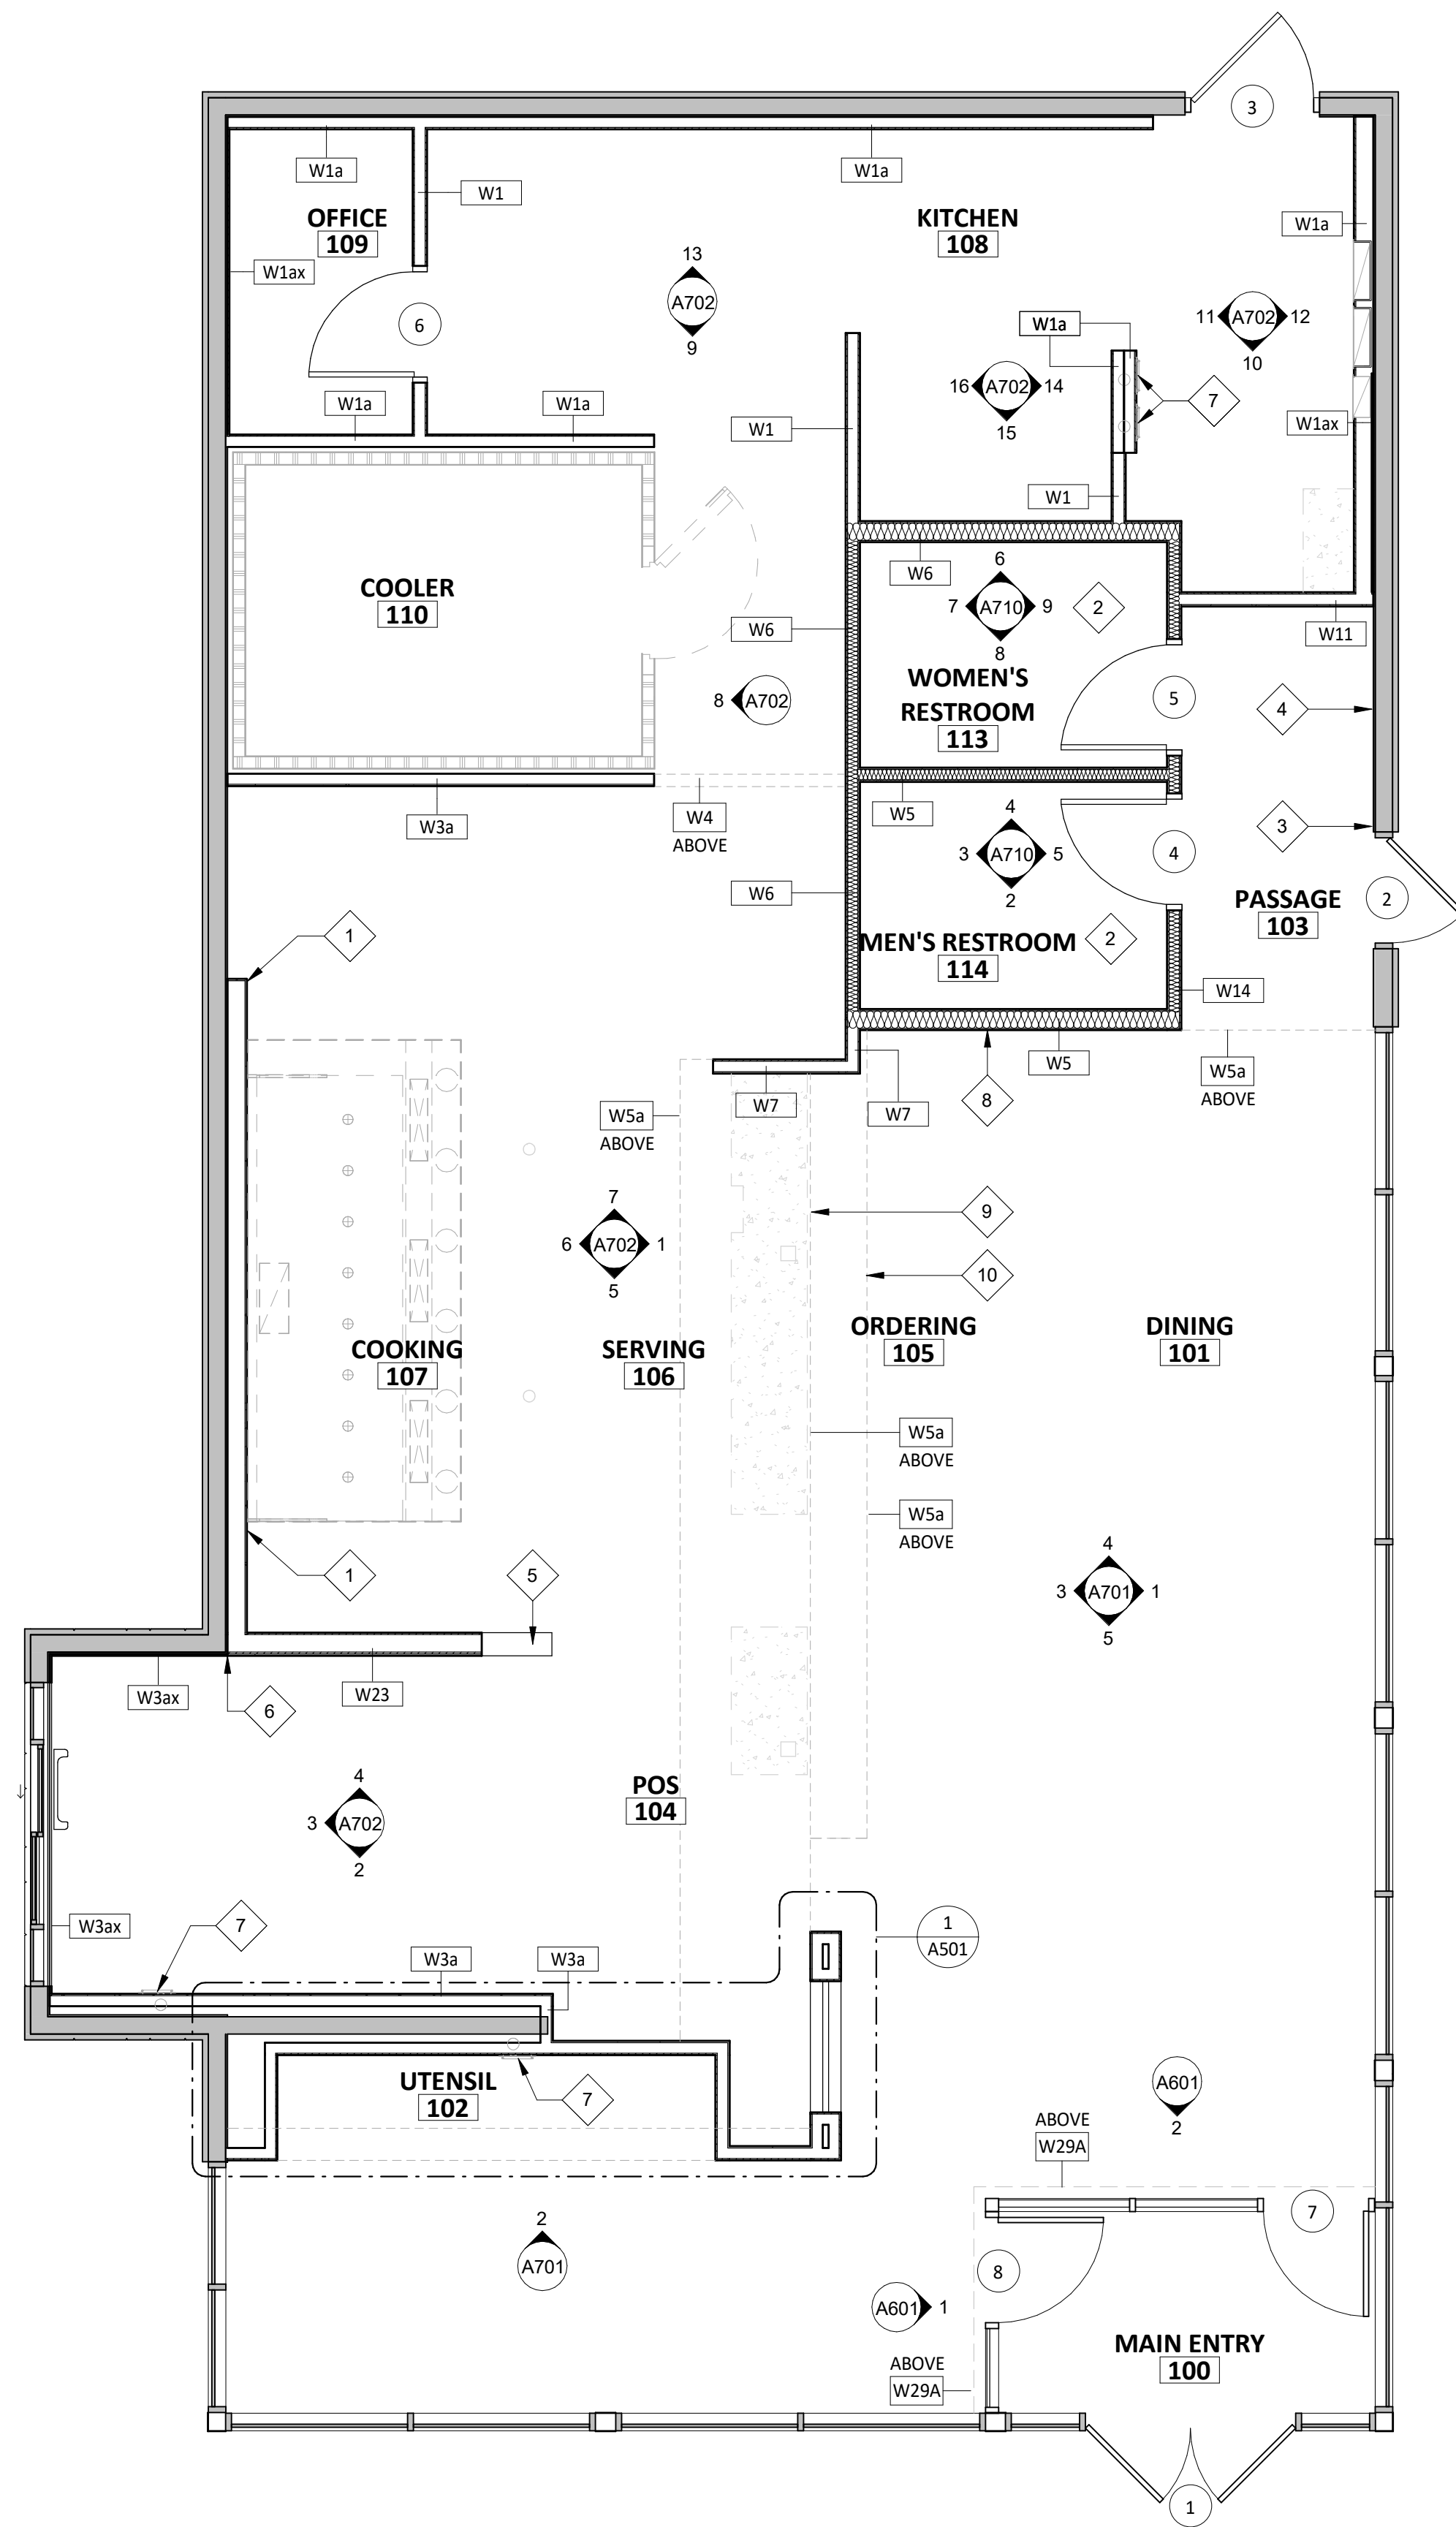

GENERAL NOTES - FLOOR PLAN

- | | |
|----|--|
| A. | ALL DIMENSIONS ARE TO FACE OF FRAMING, OR CENTERLINE OF STRUCTURE UNLESS NOTED OTHERWISE. |
| B. | ALL DIMENSIONS TO EXTERIOR OR EXISTING WALLS ARE TO THE FINISH FACE OF THE EXISTING GYP. BD. |
| C. | DASHED CIRCLE IN RESTROOM INDICATES 5'-0" TURNING DIAMETER REQUIRED BY ADA. |
| D. | REFER TO WALL FINISH LEGEND ON A120. |
| E. | IN SITUATIONS WHERE TENANT'S G.C. IS TO PROVIDE TYPE 'X' GYP. BD. FOR A RATED ASSEMBLY, THE TYPE 'X' GYP. BD. IS REQUIRED TO GO BENEATH THE SHEATHING AND FINISHES. |
| F. | SEE SHEET A801 FOR ADDITIONAL SHEATHING BEHIND CERTAIN WALL FINISHES. |
| G. | SEE A601 FOR DOOR TYPES. |
| H. | TENANT'S GENERAL CONTRACTOR TO PERFORM LAYOUT OF ENTIRE SPACE PRIOR TO STARTING FRAMING AND REPORT ANY DISCREPANCIES IN NOTED DIMENSIONS TO ARCHITECT AND CHIPOTLE MEXICAN GRILL'S CM PRIOR TO PROCEEDING. FAILURE TO ADHERE TO THESE REQUIREMENTS RESULTING IN ANY REMEDIATION REQUIRED TO MEET DESIGN INTENT WILL BE AT CONTRACTOR'S COST. |
| I. | PROVIDE FULL HEIGHT BLOCKING IN WALL FOR ALL SHELVING, TYP. |
| J. | DENSSHIELD TILE BACKER BOARD SHALL NOT BE INSTALLED OVER VAPOR BARRIERS AT EXTERIOR WALLS. |
| K. | MOISTURE RESISTANT GYP. BD. SHALL BE USED IN RESTROOMS. |
| L. | ALL STUDS ARE 3 5/8" METAL STUDS UNLESS NOTED OTHERWISE ON PLAN. |
| M. | ALL INTERIOR DOORS ARE 4" OFF OF PERPENDICULAR WALL UNLESS NOTED OTHERWISE. |

WALL TYPE LEGEND

- | | | | |
|---|---|---|---|
| NEW CONSTRUCTION |  | INDICATES LOCATION OF
ITEMS ABOVE |  |
| EXISTING CONSTRUCTION |  | DESIGNATES EXISTING
TWO (2) HOUR RATED
ASSEMBLY (BY OTHERS) |  |
| NEW CONSTRUCTION
WITH SOUND BATT
INSULATION |  | DESIGNATES WALLS &
SHEATHING TO EXTEND TO
DECK |  |
| WALK-IN COOLER |  | | |

- # KEYNOTE LEGEND
- | | |
|----|--|
| 1 | WHERE GREASE EXHAUST HOOD INTERSECTS WALLS, PROVIDE 24 GAUGE GALVANIZED METAL FROM TOP OF WALL TO 18" PAST HOOD IN ALL DIRECTIONS. |
| 2 | FOR ALL REQUIRED BLOCKING LOCATIONS, REFER TO ELEVATIONS ON A710. |
| 3 | PROVIDE 25 GAUGE GALVANIZED METAL TO 50 1/2" A.F.F. |
| 4 | PROVIDE IN-WALL BLOCKING FOR LICENSE FRAME AS REQUIRED. |
| 5 | LOCATION OF WALL PASS-THROUGH OPENING - REFER TO A702. |
| 6 | SUBSTRATE FACE TO ALIGN. |
| 7 | DRYER VENTS IN WALL FOR SODA LINES ROUTED ABOVE 4" PVC PIPES - REFER TO A801 FOR ADDITIONAL INFORMATION. |
| 8 | PROVIDE IN-WALL BLOCKING FOR ARTWORK. |
| 9 | DASHED LINES INDICATE LOCATION OF SOFFIT WALL TO DECK ABOVE - REFER TO A201 FOR ADDITIONAL INFORMATION. |
| 10 | DASHED LINES INDICATE LOCATION OF SOFFIT ABOVE - REFER TO A201 FOR ADDITIONAL INFORMATION. |
| 11 | HATCH LOCATED WITHIN WALLS AS SHOWN INDICATES THAT TOP OF FRAMING IS NOT TO EXCEED 10'-0" A.F.F. |

The logo for Wilkus Architects, featuring a stylized 'wa' in a light gray font above the word 'WILKUS' in a bold, black, sans-serif font, with 'ARCHITECTS' in a smaller, black, sans-serif font below it.

CLIENT:



CHIPOTLE MEXICAN GRILL, INC.
PO BOX 182566
COLUMBUS, OH 43218-2566
TELEPHONE: (614) 318-2482
INTERNET: WWW.CHIPOTLE.COM

COPYRIGHT 2024
THIS DRAWING IS AN INSTRUMENT OF SERVICE AND
AS SUCH REMAINS THE PROPERTY OF CHIPOTLE
MEXICAN GRILL, INC.. PERMISSION FOR USE OF THIS
DOCUMENT IS LIMITED AND CAN BE EXTENDED ONLY
BY WRITTEN AGREEMENT WITH CHIPOTLE MEXICAN
GRILL, INC..

PROJECT INFORMATION:

STORE NO.: 4757
"ANDERSON IN"
S SCATTERFIELD RD & 59TH STREET
ANDERSON, IN 46013

SEAL:



July 25, 2024

MATTHEW M. WILKUS
LICENSE #AR11700110
(EXPIRES 12/31/2024)

PROJECT NO. 2022-0494

DRAWN BY RDB

CHECKED BY

ISSUE RECORD:

12/12/2023	PERMIT SET
06/19/2024	BID SET
07/24/2024	CONSTRUCTION SET

REVISIONS:


1	05/20/2024	DB UPDATES
2	07/24/2024	CONSTRUCTION SET

TITLE:



ARCHITECTURAL
FLOOR PLAN

SHEET NUMBER:

A110

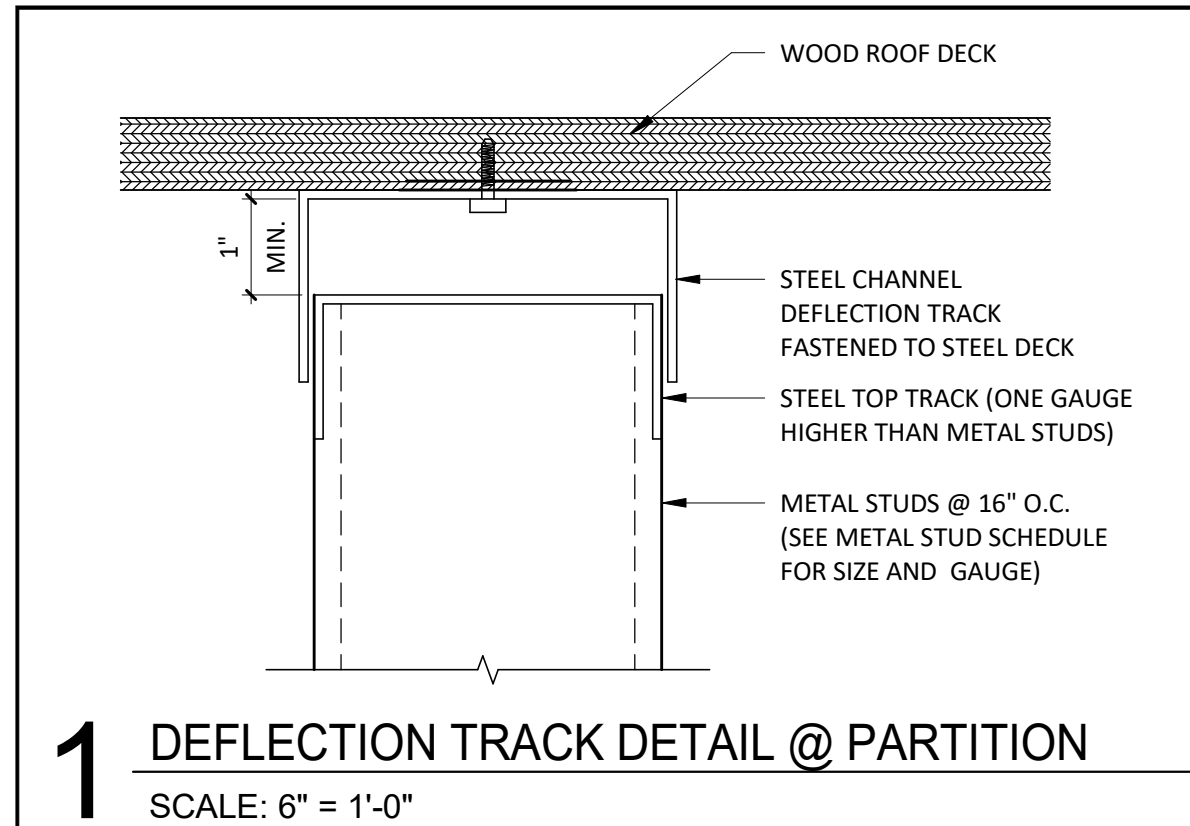


1 DEFLECTION TRACK DETAIL @ PARTITION
SCALE: 6" = 1'-0"

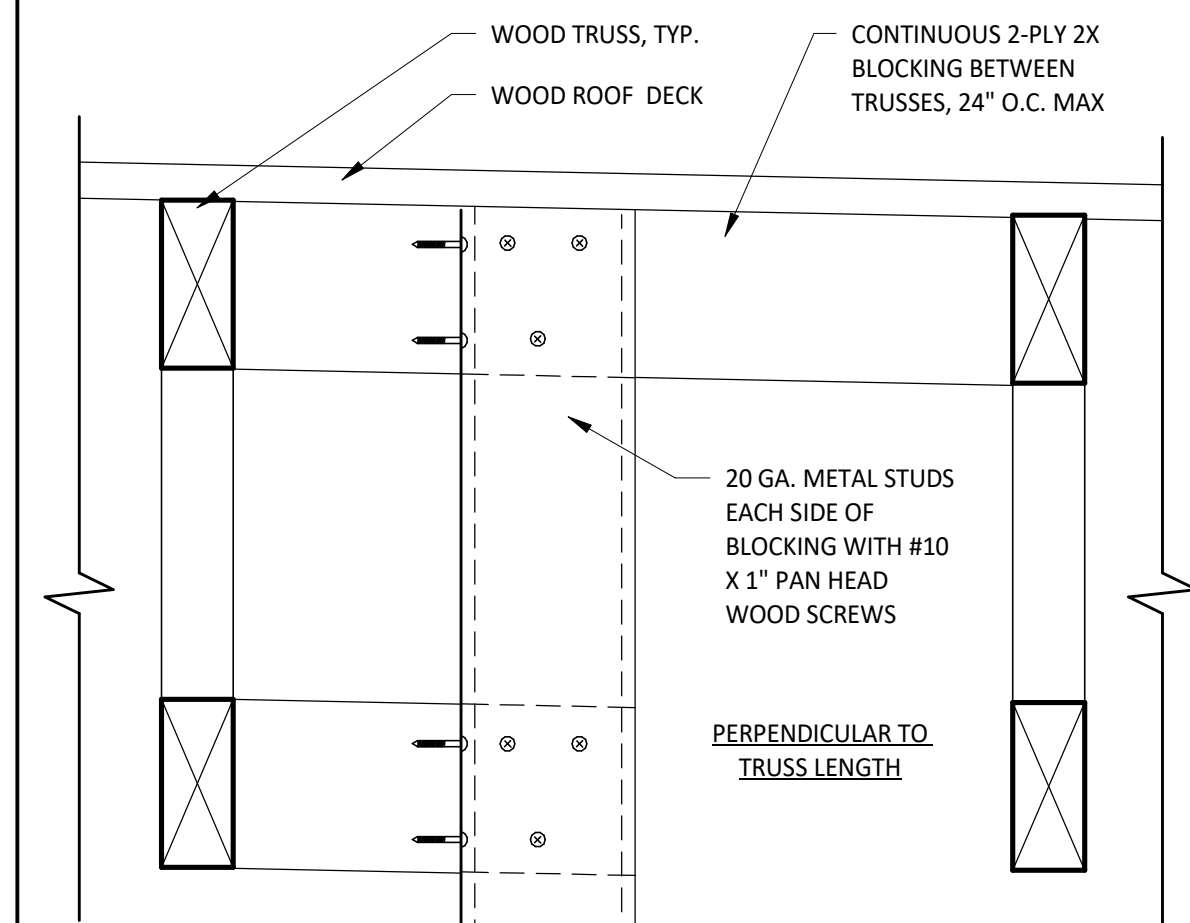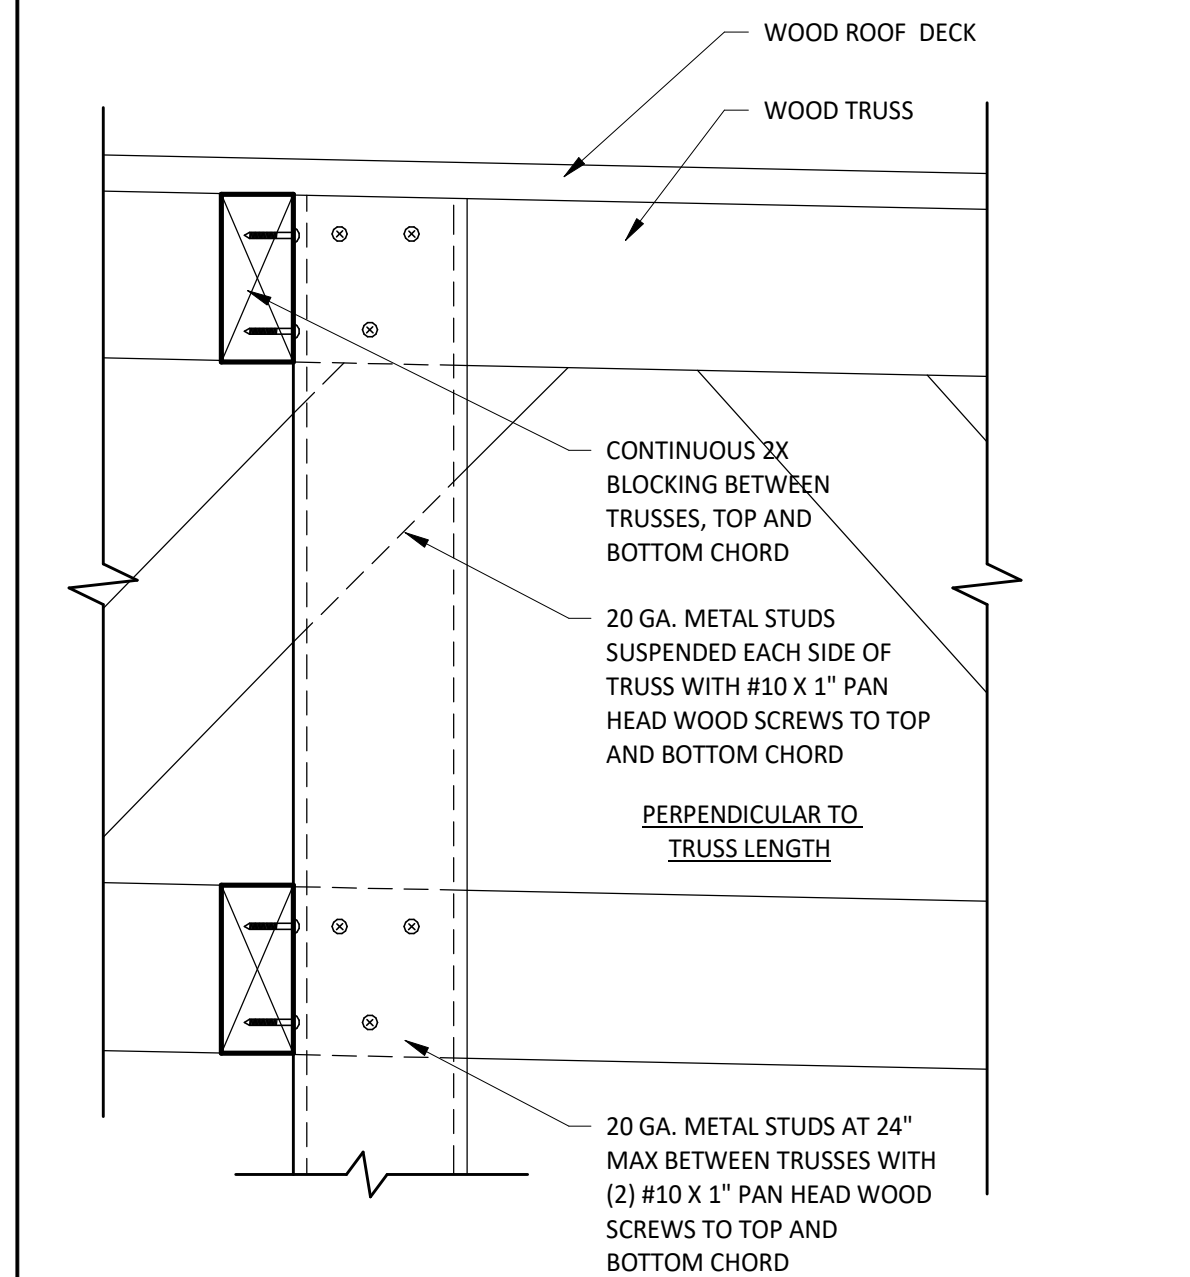


2 SOFFIT HANGING DETAIL
SCALE: 3" = 1'-0"


WALL TYPES

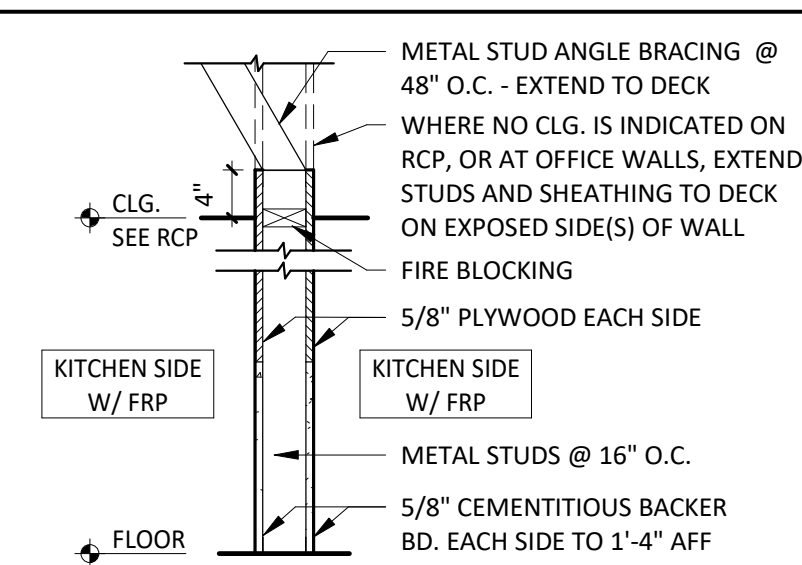


W1 INTERIOR PARTITION
W1a INTERIOR PARTITION (1-SIDE ONLY)

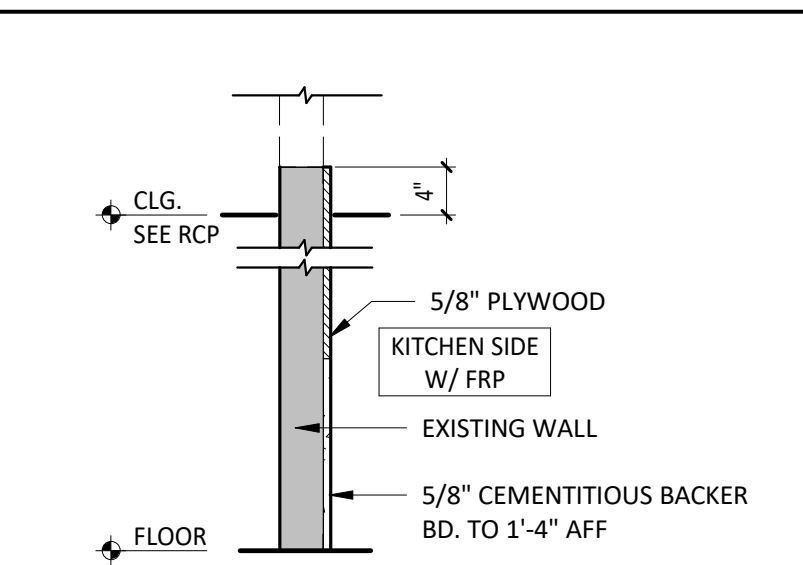


W1ax INTERIOR PARTITION (SUBSTRATE ONLY)

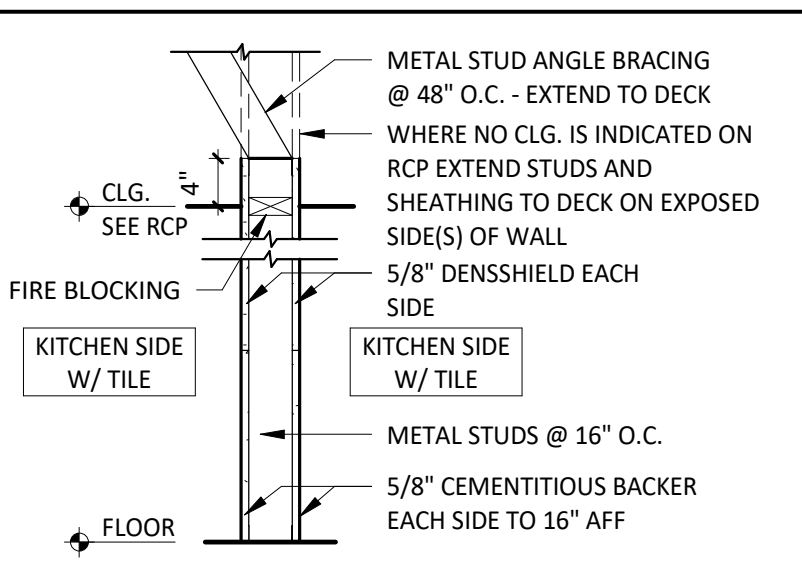


W3 INTERIOR PARTITION
W3a INTERIOR PARTITION (1-SIDE ONLY)

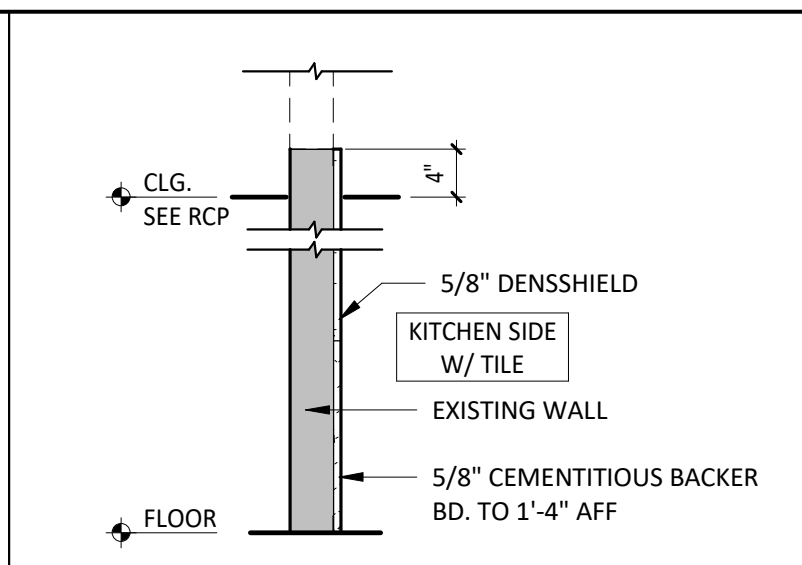


W3ax INTERIOR PARTITION (SUBSTRATE ONLY)

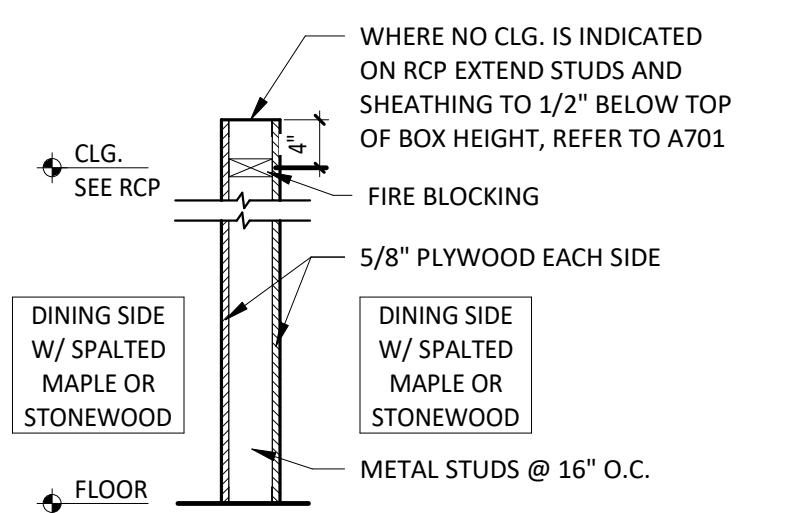


W4 INTERIOR PARTITION
W4a INTERIOR PARTITION (1-SIDE ONLY)

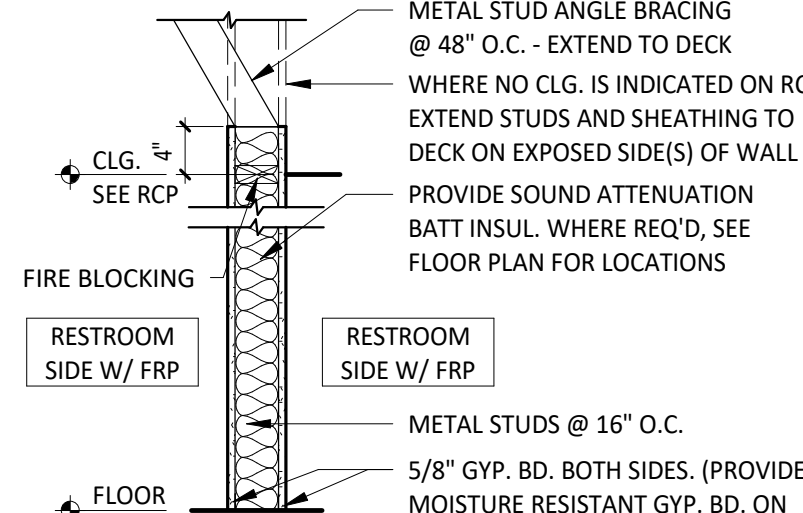


W5 INTERIOR PARTITION
W5a INTERIOR PARTITION (1-SIDE ONLY)

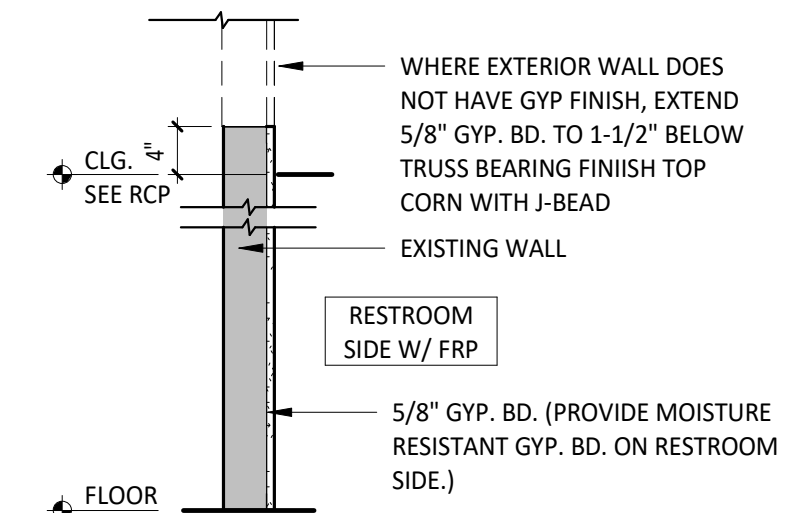


W5ax INTERIOR PARTITION (SUBSTRATE ONLY)

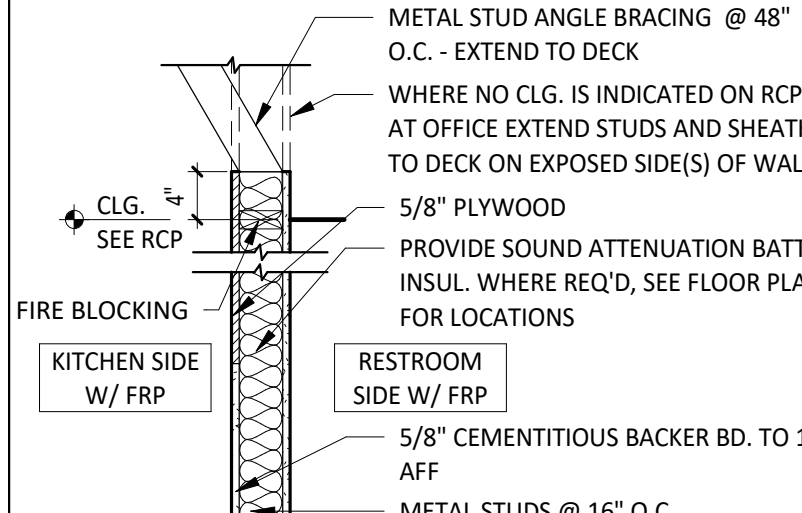


W6 INTERIOR PARTITION

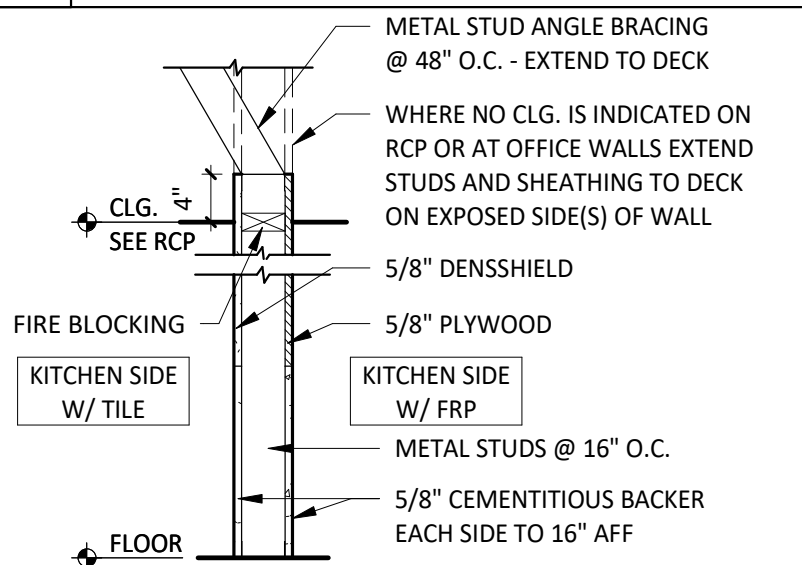


W7 INTERIOR PARTITION

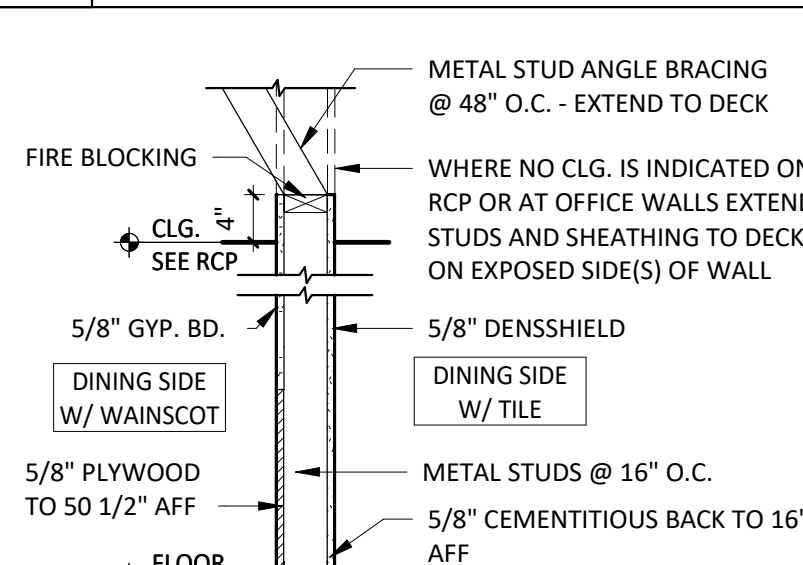


W8 INTERIOR PARTITION

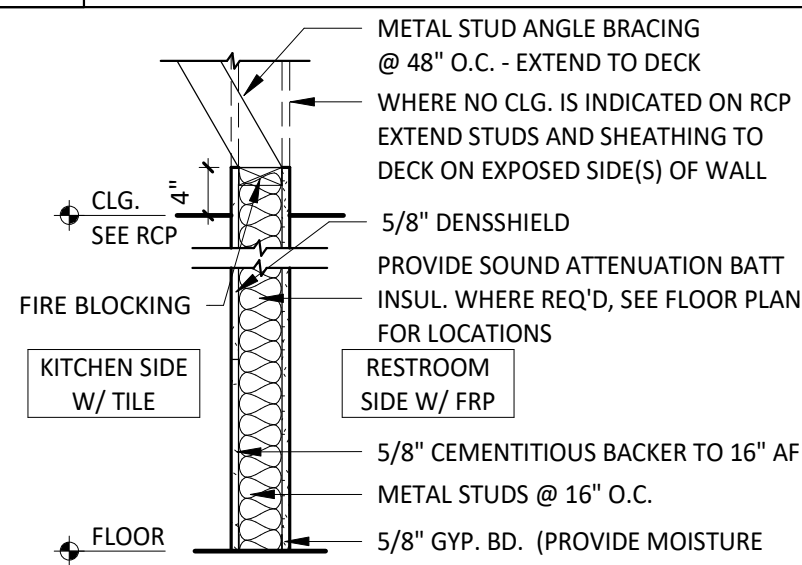


W9 INTERIOR PARTITION

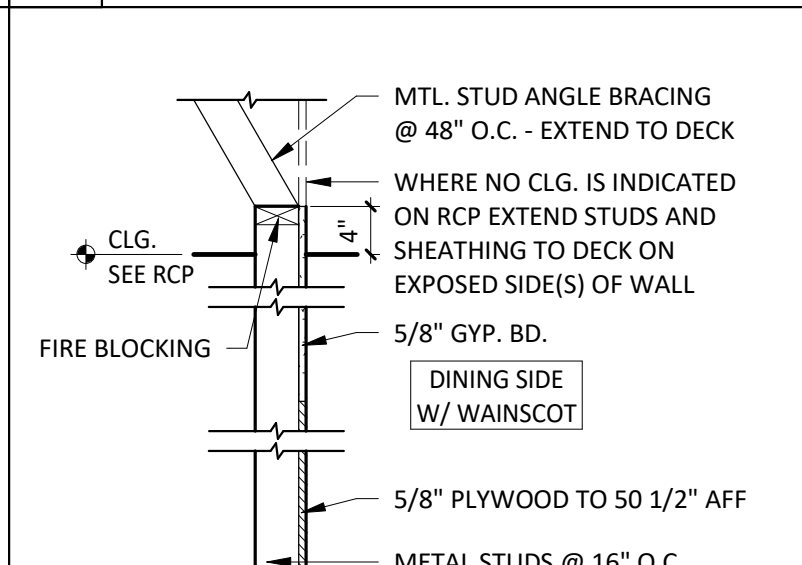


W10a INTERIOR PARTITION

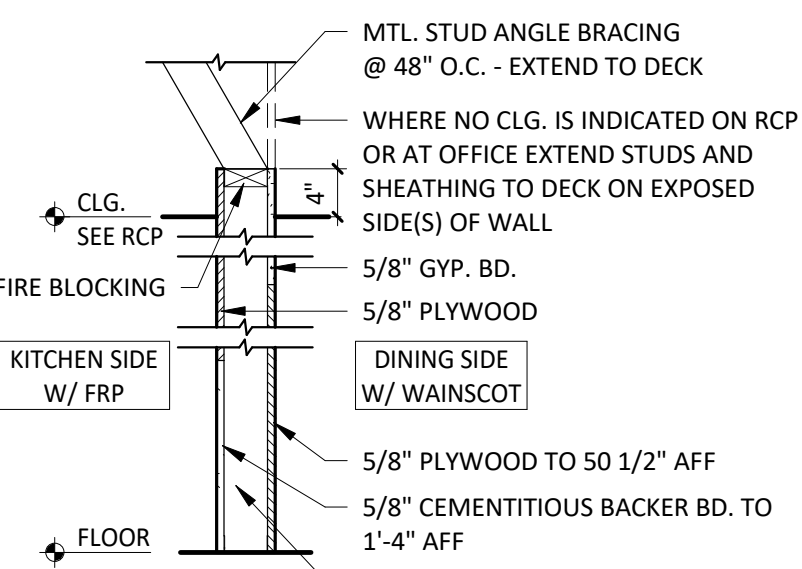


W11 INTERIOR PARTITION

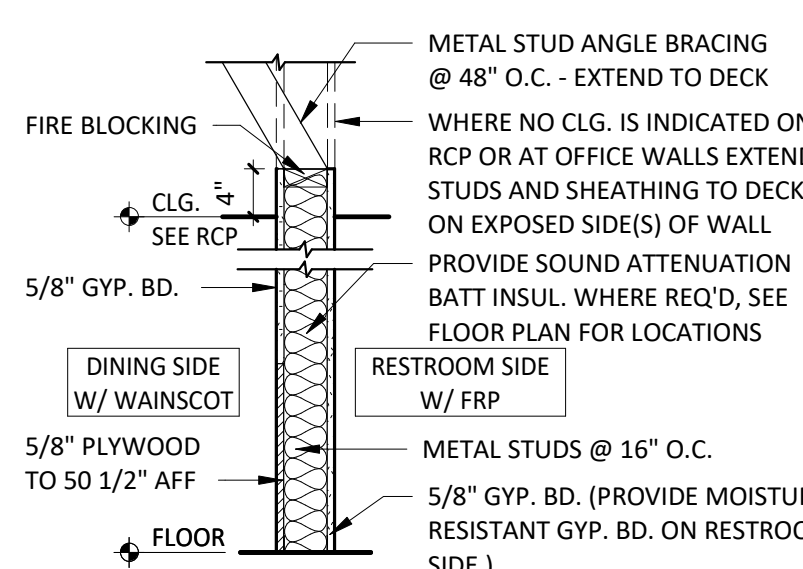


W14 INTERIOR PARTITION

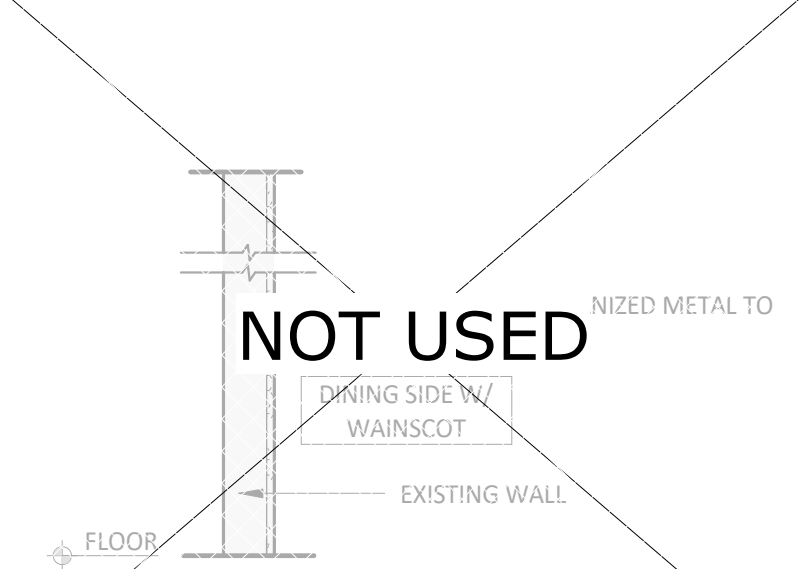


W16ax INTERIOR PARTITION

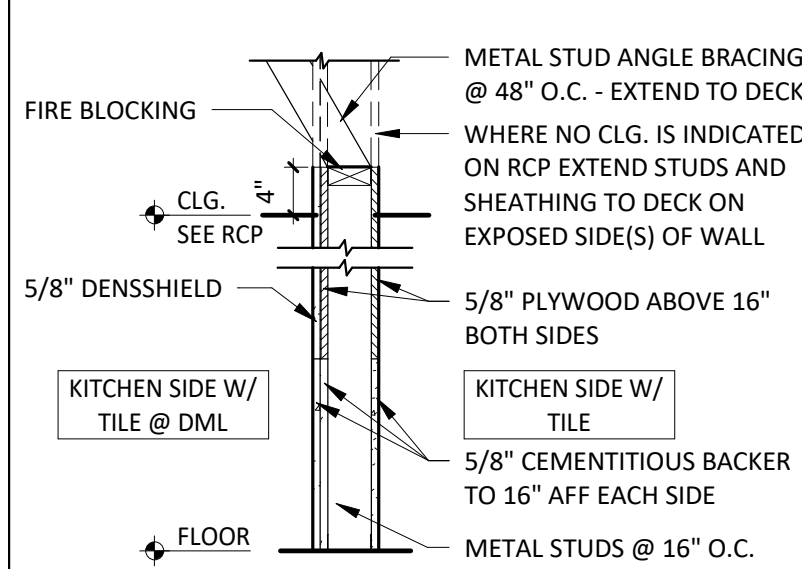


W23 INTERIOR PARTITION

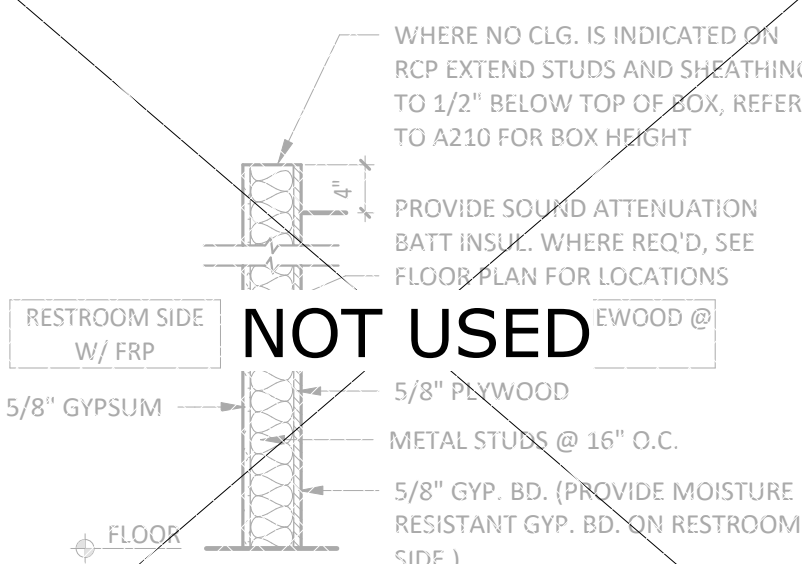


W24 INTERIOR PARTITION

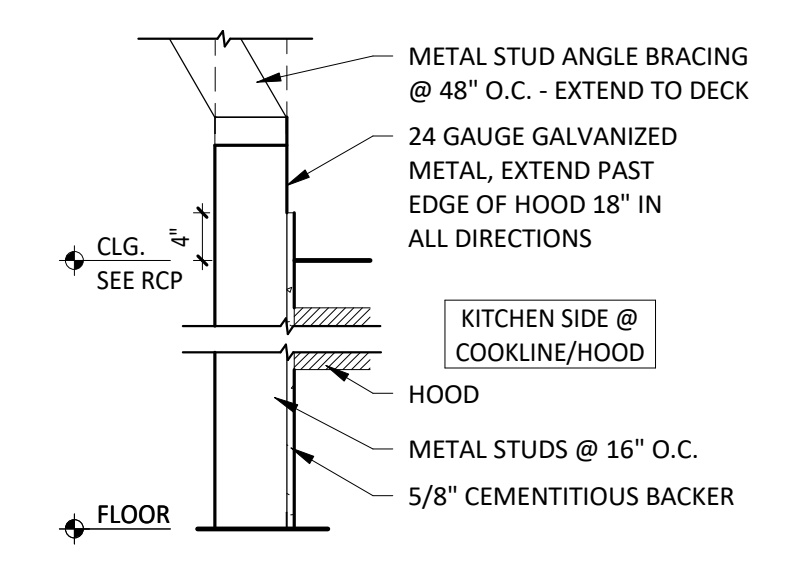


W26a INTERIOR PARTITION

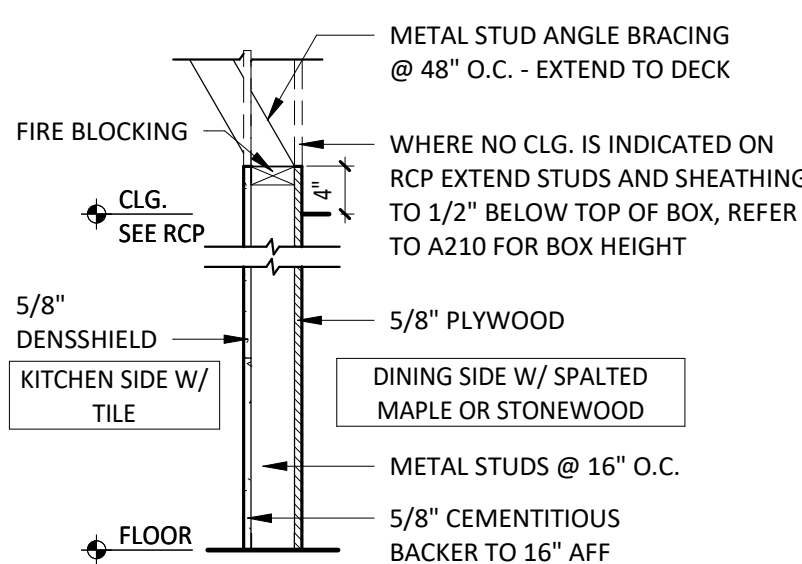


W28 INTERIOR PARTITION

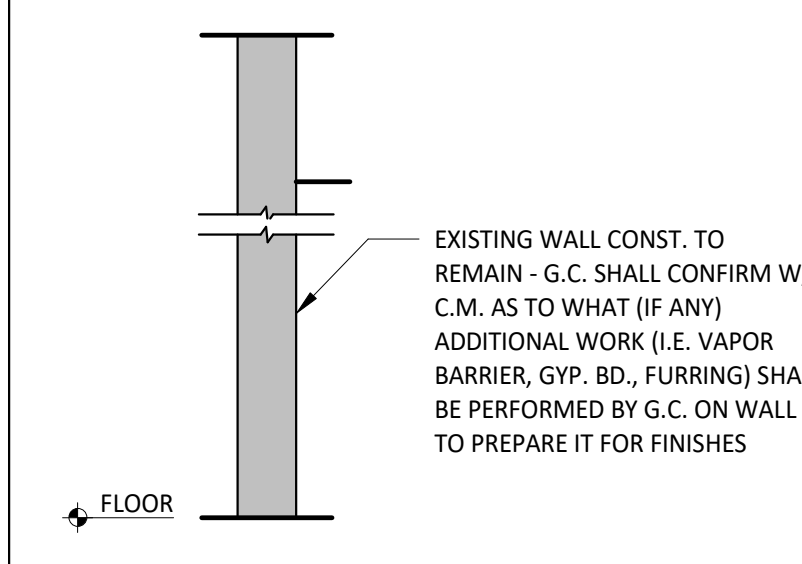

Wx EXISTING WALL

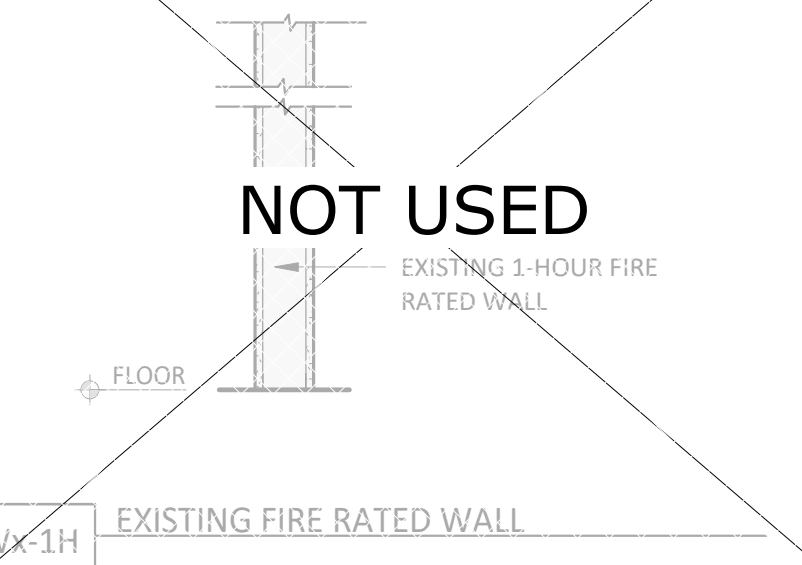

Wx-1H EXISTING FIRE RATED WALL

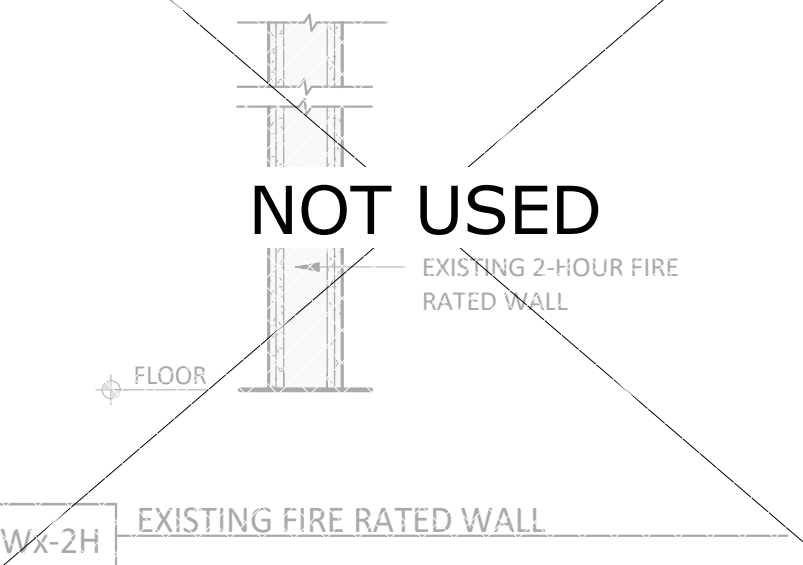

Wx-2H EXISTING FIRE RATED WALL

GENERAL NOTES - WALL TYPES

- REFER TO FINISH SCHEDULE AND CERAMIC TILE WALL FINISHES KEY PLAN ON SHEET A120 FOR WALL FINISHES, REFER TO FLOOR PLAN ON A110 FOR METAL STUD SIZE.
- G.C. SHALL PROVIDE SOLID BLOCKING IN WALLS AS REQUIRED OR AS NEEDED.
- STUDS ARE 3 3/8" METAL STUDS UNLESS OTHERWISE NOTED ON PLAN.


STUD SCHEDULE & NOTES

- ALL HEIGHTS REFER TO UN-BRACED HEIGHTS.
- ALL HEIGHTS BASED ON 16" O.C. SPACING.
- BOTTOM TRACK TO BE SAME GAUGE AS STUD.
- TOP TRACK TO BE ONE GAUGE HIGHER.

SIZE/TYPE	W/O HUNG SHELVING	W/ HUNG SHELVING
362S125-18	UP TO 12'-0"	
362S137-33	UP TO 16'-0"	UP TO 12'-0"
600S137-33	UP TO 22'-0"	UP TO 16'-0"
600S162-43	UP TO 26'-0"	UP TO 22'-0"

PARTITION NOTES

- ALL METAL STUDS TO CONFORM TO LOCAL BUILDING CODES.
- ALL STUD WALLS AND PARTITIONS REQUIRE GYP. BOARD ON BOTH SIDES FOR THE FULL HEIGHT OF THE STUDS UNLESS SPECIFICALLY DETAILED OTHERWISE.
- ALL SUSPENDED WALLS SHALL HAVE GYP. BOARD WHICH EXTENDS 4" ABOVE THE SUSPENDED CEILING UNLESS SHOWN AND/OR NOTED OTHERWISE BY THE ARCHITECT.
- FIRE RETARDANT PLYWOOD MAY SUBSTITUTE FOR GYP. BOARD WHERE SO DIRECTED BY THE ARCHITECT.
- ALL STUD WALLS AND PARTITIONS SHALL HAVE CONTINUOUS LINES OF BRIDGING SPACED AT 4'-0" MAXIMUM ON CENTER. THE BRIDGING SHALL BE SECURELY FASTENED TO THE STUDS WITH EITHER SCREWS OR WELDS. REFER TO DETAILS THIS SHEET.
- ALL STUDS SHALL BE "CEE" STUDS WITH FLANGE STIFFENERS.
- THE MATERIALS AND DETAILS SHOWN ARE FOR TYPICAL INSTALLATIONS. WHERE THE STUD MANUFACTURER'S RECOMMENDATIONS OR LOCAL ORDINANCES ARE MORE RESTRICTIVE, THEY SHALL APPLY.
- TYPICAL FASTENER:
A: STEEL STUDS TO STEEL STUDS OR TRACKS:
20 GAUGE - #8 - 18 X 1 1/2" TEKS WITH PHILIPS PAN HEAD - MIN. 2 PER CONNECTION
18/16 GAUGE - #10 - 16 X 3/4" TEKS WITH PHILIPS PAN HEAD - MIN. 3 PER CONNECTION
B: STEEL STUDS OR TRACKS TO WOOD PURLINS, GIRDERS AND BEAMS:
#14 - 10 X 1 1/2" H.W.H. TYPE "S" METAL-TO-WOOD TEKS AT 12" O.C., 2" FROM EACH END
C: STEEL STUDS OR TRACKS TO STRUCTURAL STEEL (TUBE/WIDE FLANGE COL'S, BM'S, GIRDER'S, ETC.)
0.145" DIA. HILTI X-EDNI FASTENERS, 5/8" MIN. LENGTH AND MIN. OF 2 PER CONNECTION, OR 2 ROWS AT 16" O.C. FOR CONTINUOUS APPLICATIONS SUCH AS TRACKS, U.N.O.
D: PLYWOOD TO STEEL STUDS:
#10 - 24 X 1 1/4" TEKS/3 (PLYMETALTEKS) WITH THIN WAFER HEAD - 24" O.C. FILED, 12" O.C. PERIMETER
E: GYPSUM BOARD TO STEEL STUDS:
#7 X 1 1/4" HI-LOW TYPE "S" BUGLE HEAD SCREWS FOR 3/8" TO 5/8" GYPSUM BOARD TO 25 GAUGE OR 20 GAUGE STUDS
#6 X 1 1/4" TYPE S-12 BUGLE HEAD SCREWS FOR 3/8" TO 5/8" TO 18 GAUGE OR 16 GAUGE STUDS OR TRACKS
FIELD - 12" O.C. CEILINGS, 24" O.C. WALLS
BUTT JOINTS 12" O.C.
F: STEEL STUDS OR TRACKS TO CONCRETE:
0.145" DIA. HILTI X-DNI FASTENER, 1" MIN. LENGTH, 2 ROWS AT 16" O.C.

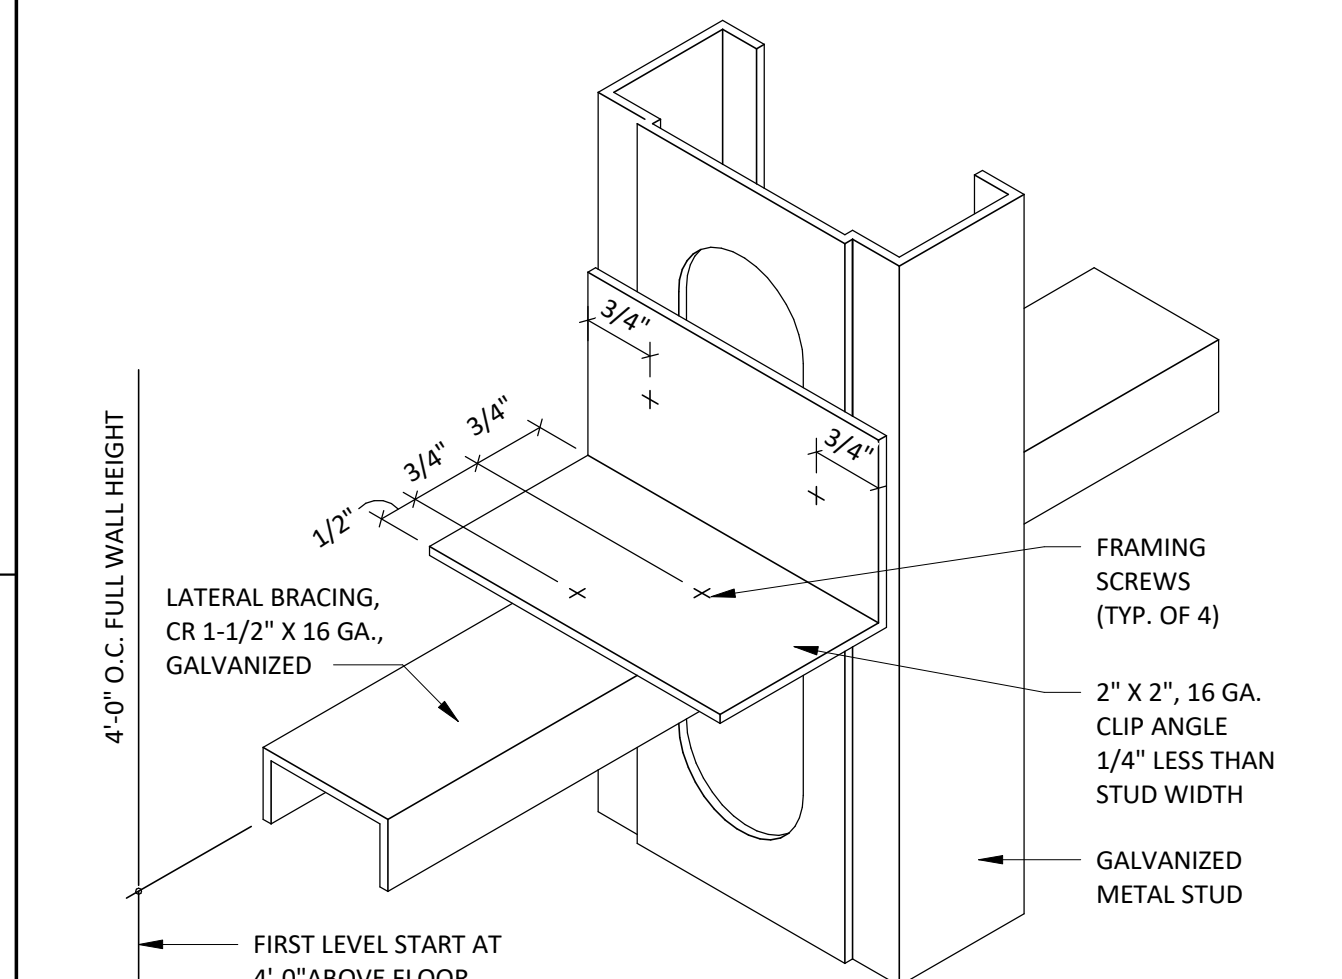


3 LATERAL BRACING DETAIL @ PARTITION
SCALE: NOT TO SCALE



COPYRIGHT 2024
THIS DRAWING IS AN INSTRUMENT OF SERVICE AND
AS SUCH REMAINS THE PROPERTY OF CHIPOTLE
MEXICAN GRILL, INC. PERMISSION FOR USE OF THIS
DOCUMENT IS LIMITED AND CAN BE EXTENDED ONLY
BY WRITTEN AGREEMENT WITH CHIPOTLE MEXICAN
GRILL, INC.

PROJECT INFORMATION:


STORE NO.: 4757
"ANDERSON IN"
S SCATTERFIELD RD & 59TH STREET
ANDERSON, IN 46013

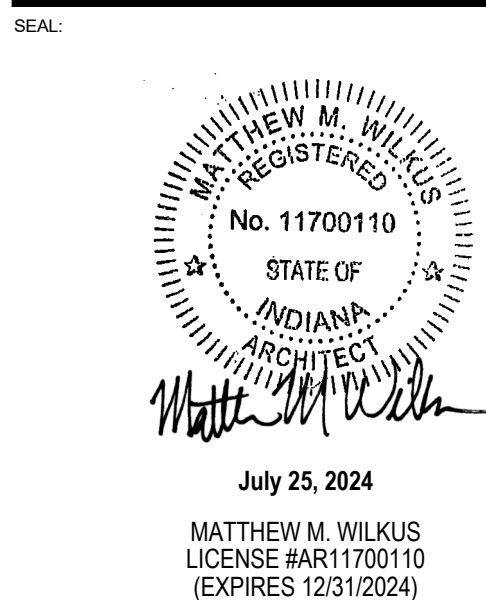

PROJECT NO. 2022-0494
DRAWN BY RDB
CHECKED BY

ISSUE RECORD:
12/12/2023 PERMIT SET
06/19/2024 BID SET
07/24/2024 CONSTRUCTION SET

REVISIONS:
1
2
3
1173
117

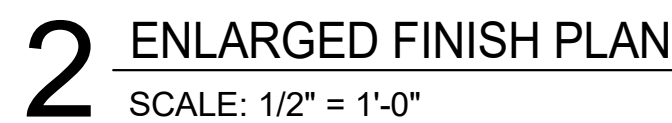

LGD. #	FLOOR FINISHES	LGD. #	WALL BASE FINISHES	LGD. #	CEILING/DECK FINISHES
F1	POLISHED CONCRETE	B1	BLACK RUBBER, COVELESS	C1	OPEN TO STRUCTURE, UNPAINTED
F2	QUARRY TILE	B2	QUARRY TILE, COVE	C2	STONEWOOD
F3	EXISTING EXTERIOR CONCRETE	B3	BLACK RUBBER, COVE	C3	GYP BD; PAINT "MOONLIT SNOW"
F4	SEALED CONCRETE	B4	QUARRY TILE, COVELESS	C4	2X4 VINYL-FACED LAY-IN
F5	RESINOUS FLOORING	B5	CERAMIC TILE	C5	NOT USED
F6	PORCELAIN TILE				
LGD. #	DOOR FINISHES	LGD. #	WALL BASE FINISHES		
D1	PAINT "BLACK"	P1	GYP BD; PAINT "MOONLIT SNOW"		
D2	PAINT "KNIGHTS ARMOR"	P2	FIBERGLASS REINFORCED PANELS TO 4'-0" AFF (SMOOTH)		
		P3	GYP BD; PAINT "THIN ICE", EGGSHELL, REFER TO A701 AND A710		
		P4	GYP BD; PAINT "THIN ICE", SEMI-GLOSS BELOW 4'-3" AFF		
		P5	CERAMIC TILE - WHITE		
		P6	FIBERGLASS REINFORCED PANELS (PEBBLED FINISH)		
		P7	NOT USED		
		P8	NOT USED		
		P9	SPALTED MAPLE WALL PANEL, HORIZONTAL GRAIN		
		P10	EXISTING STOREFRONT		
		P11	STONEWOOD WALL PANEL		
		P12	EXISTING PREFINISHED BRAKE METAL		
		P13	STAINLESS STEEL		

B.	SPALTED MAPLE PANELS PROVIDED BY TMS, INSTALLED BY GC.
C.	GC IS RESPONSIBLE FOR SEQUENCING OF PREWIRING WITH COMPLETION OF INTERIOR FINISHES (GYP. BD. FINISHES).
D.	PROVIDE WATER PROOFING MEMBRANE, REFER TO A802 DETAILS. PROVIDE ON INTERIOR OF ALL RESTROOM WALLS, REFER TO A801 DETAILS
E.	GC SHALL PROVIDE STAINLESS STEEL BASE AT ALL OUTSIDE QUARRY TILE CORNERS IN KITCHEN ONLY - REFER TO SPECIFICATIONS AND A802 FOR DETAILS.


SC = PROVIDE A SCHLUTER QUADEK METAL CORNER AT ALL TILED CORNERS - REFER TO A802 FOR ADDITIONAL INFORMATION

CG = PROVIDE 1 1/2" X 1 1/2" STAINLESS STEEL CORNER GUARD UP TO 5'-0" A.F.F. - 1 1/2" X 1 1/2" FRP CORNER GUARD FROM TOP TO CEILING- REFER TO A802 FOR ADDITIONAL INFORMATION


END = PROVIDE END GUARD - REFER TO A802 FOR ADDITIONAL INFORMATION

1	PROVIDE STAINLESS STEEL ON WALL TO 24" ABOVE TOP OF MOP SINK WITH FRP ABOVE - FLASH BOTTOM EDGE OVER MOP SINK RIM - BEND STAINLESS STEEL AT INSIDE CORNER SO THERE IS NO JOINT - REFER TO A801 FOR ADDITIONAL INFORMATION.
2	GENERAL CONTRACTOR TO PROVIDE 18 GAUGE STAINLESS STEEL SHROUD AROUND EXPOSED LINES AT ICE MAKER.
3	PROVIDE QUARRY TILE ON TOP OF CURB FOR SMART SAFE - PROVIDE BULLNOSE TILE TO LAP OVER TOP CUT EDGE OF BASE TILE - REFER TO A802 FOR ADDITIONAL INFORMATION - GENERAL CONTRACTOR TO COORDINATE EXTENT OF QUARRY TILE WITH KES PRIOR TO INSTALLATION
4	FRP ENCLOSURE PANEL AT COOLER GAP - REFER TO A801 FOR ADDITIONAL INFORMATION.
5	ALUMINUM PLATE BELOW DRIVE-THRU WINDOW - REFER TO A802 FOR ADDITIONAL INFORMATION.
6	CONCRETE CURB FOR EQUIPMENT WITH QUARRY TILE BASE AT ALL EXPOSED EDGES.
7	EXTENT OF QUARRY TILE FROM KITCHEN.
8	EXTENT OF RESINOUS FLOOR FROM RESTROOMS - ALIGN EDGE OF FLOOR WITH CENTER OF DOOR JAMB.
9	PROVIDE TOP CORNER AT TRANSITION FROM GYPSUM BOARD CEILING TO FRP WALL - REFER TO A210 FOR ADDITIONAL INFORMATION.



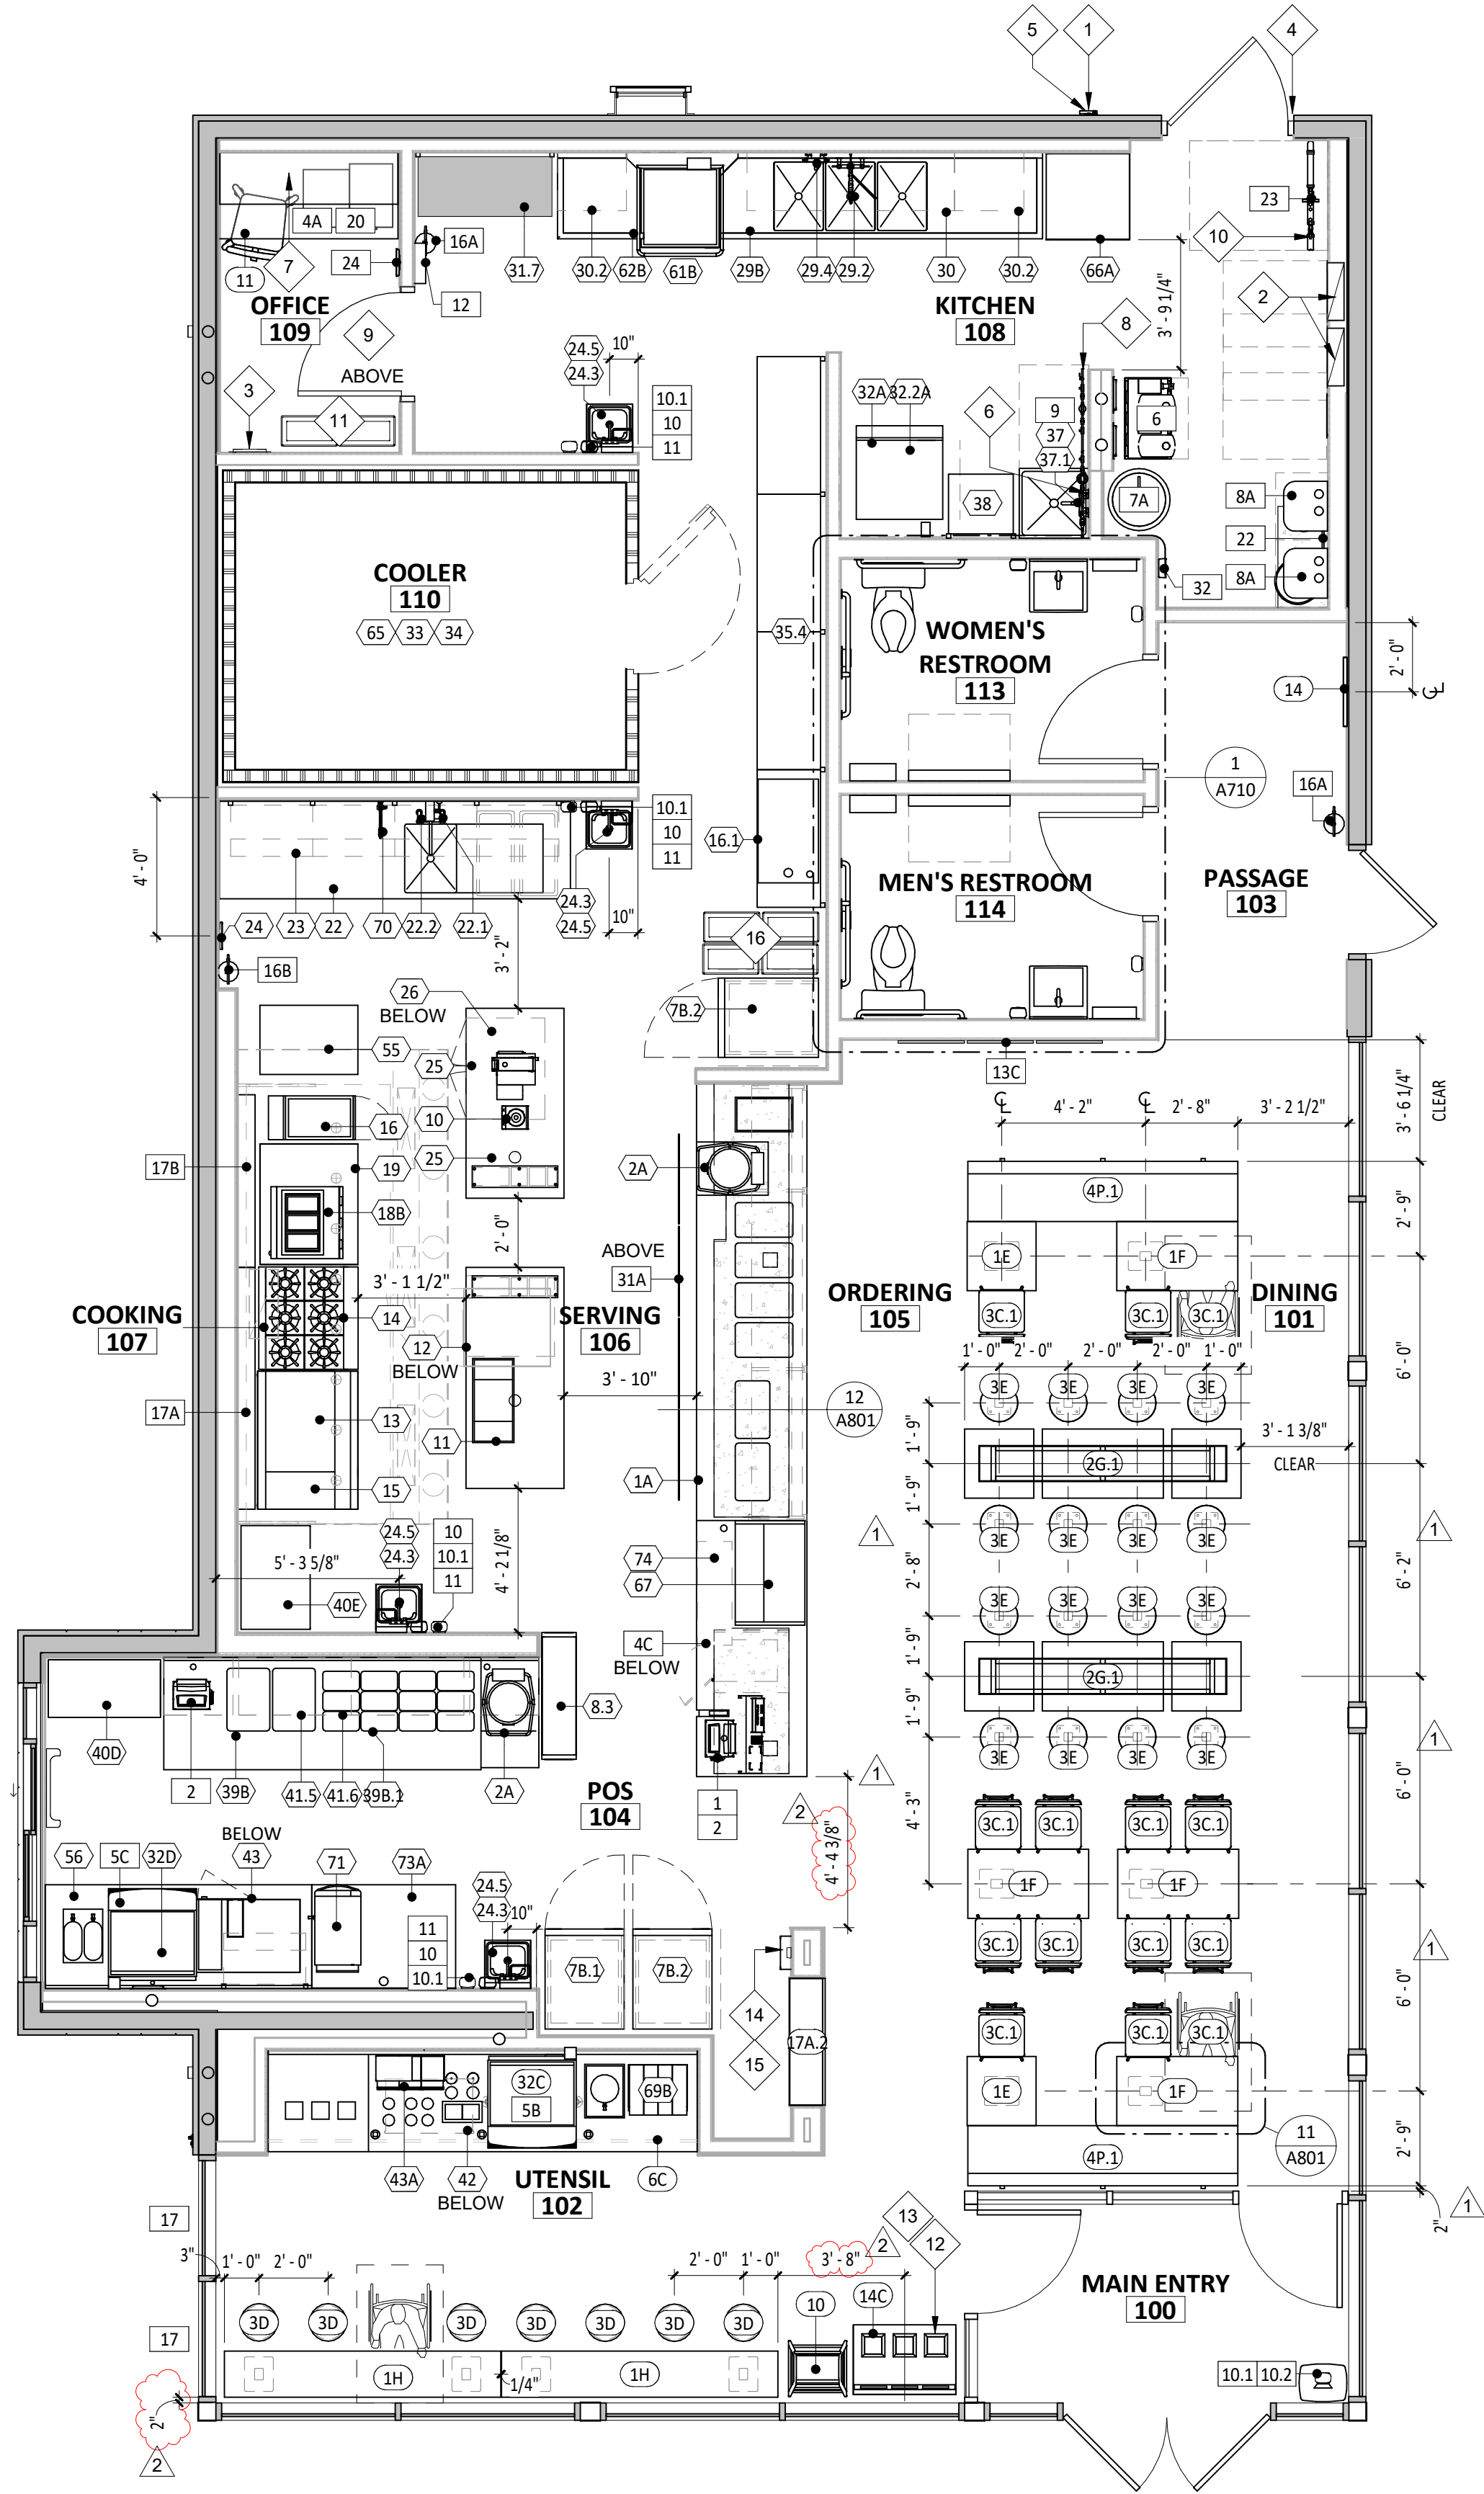

 1 FURNITURE, FIXTURE, & EQUIPMENT PLAN
SCALE: 1/4" = 1'-0"



2 FURNITURE, FIXTURE & EQUIPMENT PATIO PLAN
SCALE: 1/4" = 1'-0"



GENERAL NOTES - FF& E

- REFER TO SHEET A131 FOR EQUIPMENT LIST AND FURNITURE SCHEDULE.
- ALL DIMENSIONS TO EXTERIOR OR EXISTING WALLS ARE TO THE FINISH FACE OF THE EXISTING GYP. BD.
- ALL DIMENSIONS ARE TO FACE OF FRAMING, EDGE OF EQUIPMENT, OR CENTERLINE OF EQUIPMENT UNLESS NOTED OTHERWISE.
- ALL FURNITURE TO BE SQUARE/PARALLEL TO TENANT SPACE/WALLS AS SHOWN ON PLANS.

KEYNOTE LEGEND

- CO2 REMOTE FILLER - VERIFY FINAL LOCATION WITH CHIPOTLE'S CONSTRUCTION MANAGER.
- ELECTRICAL PANEL LOCATION - SEE ELECTRICAL PLANS FOR ADDITIONAL INFORMATION.
- BYPASS DISTRIBUTION PANEL - SEE ELECTRICAL PLANS FOR ADDITIONAL INFORMATION.
- DOORBELL LOCATION - INSTALL BETWEEN 36" AND 48" A.F.F. - REFER TO ELECTRICAL PLANS FOR ADDITIONAL INFORMATION.
- HOSE BIBB - REFER TO PLUMBING PLANS FOR ADDITIONAL INFORMATION.
- CHEMICAL CLEANING DISPENSING SYSTEM WITH INTEGRAL AIR GAP - REFER TO PLUMBING PLANS FOR ADDITIONAL INFORMATION.
- OFFICE DESK AND SHELVING - REFER TO SHEET A702 AND ELECTRICAL PLANS FOR ADDITIONAL INFORMATION.
- WATER FILTER ABOVE - REFER TO PLUMBING DRAWINGS FOR ADDITIONAL INFORMATION.
- TELEPHONE BOARD ABOVE - REFER TO ELECTRICAL DRAWINGS FOR ADDITIONAL INFORMATION.
- BACKFLOW PREVENTER - REFER TO PLUMBING DRAWINGS FOR ADDITIONAL INFORMATION.
- MOVEABLE BACK-UP TRASH BINS FOR DINING AREA TRASH SURROUNDS - TYPICAL OF TWO (2).
- HOLD TRASH SURROUND OFF 2" AROUND ADJACENT WALL SURFACES - TYPICAL.
- ALIGN TRASH SURROUND WITH EDGE OF DOOR.
- KRONOS TIMECLOCK WILL BE LOCATED 44" A.F.F. TO THE TOP OF UNIT - CENTER KRONOS UNIT IN WALL - REFER TO ELECTRICAL DRAWINGS.
- ANSUL PULL TO BE LOCATED 48" A.F.F. TO THE CENTER OF UNIT ABOVE THE TIMECLOCK LOCATION.
- MOVEABLE LINEN BINS WITH LID - TYPICAL OF FOUR (4).



CLIENT:



CHIPOTLE MEXICAN GRILL, INC.
PO BOX 18296
COLUMBUS, OH 43218-2568
TELEPHONE: (614) 318-2682
INTERNET: WWW.CHIPOTLE.COM

COPYRIGHT 2024
THIS DRAWING IS AN INSTRUMENT OF SERVICE AND AS SUCH REMAINS THE PROPERTY OF CHIPOTLE MEXICAN GRILL, INC. PERMISSION FOR USE OF THIS DOCUMENT IS LIMITED AND CAN BE EXTENDED ONLY BY WRITTEN AGREEMENT WITH CHIPOTLE MEXICAN GRILL, INC.

PROJECT INFORMATION:

STORE NO.: 4757
"ANDERSON IN"
S SCATTERFIELD RD & 59TH STREET
ANDERSON, IN 46013

SEAL:



July 25, 2024

MATTHEW M. WILKUS
LICENSE #A11700110
(EXPIRES 12/31/2024)

PROJECT NO. 2022-0494

DRAWN BY RDB

CHECKED BY

ISSUE RECORD:

12/12/2023	PERMIT SET
06/19/2024	BID SET
07/24/2024	CONSTRUCTION SET

REVISIONS:

1	05/20/2024	DB UPDATES
2	07/24/2024	CONSTRUCTION SET

TITLE:

FF&E PLAN

SHEET NUMBER:

A130

KITCHEN EQUIPMENT LIST

TAG	DESCRIPTION	MANUFACTURER	MODEL NO.	QTY	FURNISHED BY	INSTALLED BY	ELEC	GAS	WATER	SEWER	REMARKS
1.1	Sneeze Guard Serve Line 12 Pan (Right)	BSI	Custom-R	1	TMS	TMS/GC					
1A	M4.0 - Front Serve Line - 12 Pan - RTD - POS Right	Defield	12 Pan Serve Line POS RTD_241x38.Sin (Right)	1	KES	KES; GC	●			●	Installed On Concrete Curb
2A	Tortilla Warmer	Caliente Industries	A2	2	KES	KES	●				GC To Store In Walk-In Cooler Until Final Installation
6	Cup Dispenser	Dispense-Rite	CHIP-ECL-3B	1	KES	KES; GC					Installed At POS Counter
7B.1	Upright Beverage Cooler, Single Door, Hinge Left	Varies	Varies - Solid Door	1	KES	KES	●				
7B.2	Upright Beverage Cooler, Single Door, Hinge Right	Varies	Varies - Solid Door	2	KES	KES	●				
8.3	M4.5 Chip Shelf	Trimark	Custom	1	KES	KES					
10	Blender	Vitamix	748	1	T	T	●				GC To Store In Walk-In Cooler Until Final Installation
11	Carving Station - 77x34in - Horizontal Well - Right	Defield	77x34in Carving Station-RT	1	KES	KES	●				
12	Undercounter Refrigerator	Hoshizaki	CRM27-LP	1	KES	KES	●				
13	Grill 48in - Natural Gas - Divider Left	Woodstone	WS-PL-48-36-4-CT-Left	1	KES	KES	●	●			
13.1	Woodstone Grease Splash Guard	Nationwide Fab; Marlo Mfg	CHP-GCG-GSG	1	KES	KES					Verify If Required
14	Range 6 Burner - Natural Gas	Garland	U36-6S	1	KES	KES		●			
15	Woodstone Grill Stand 48x31in - Divider Left	Woodstone	000-PL-STAND-CASTER	1	KES	KES					
16	Fryer - Gas - Standard Efficiency	Varies	Varies	1	KES	KES	●	●			Mounted On Legs, G.C. To Pin Front Legs To Floor
16.1	Grease Caddy	American Welding	Chipotle Grease Caddy	1	KES	KES					
17A	Cook Line Stand Off - 84x6	Nationwide Fab; Marlo Mfg	CHP-7WS-6	1	KES	KES					Mount Top of Flat Surface at 33" AFF, Install Screws at Each Stud Location, Provide Blocking To Mount To Wall
17B	Cook Line Stand Off - 60x6	Nationwide Fab; Marlo Mfg	CHP-5WS-6	1	KES	KES					Mount Top of Flat Surface at 33" AFF, Install Screws at Each Stud Location
18B	Gas Rice Cooker	Woodstone	WS-RGC-60	1	KES	GC	●	●			Final Connection by GC. RE:Mechanical Drawings
19	Rice Cooker Stand - Left	Nationwide Fab; Marlo Mfg	CHP-RCS-42ES-34	1	KES	KES					
22	Prep Sink - Corner - Left	Trimark	S1-122x34-US-FF-L	1	KES	GC				●	
22.1	Prep Sink Faucet Big Flow Faucet	T&S	B-0293-01	1	KES	GC			●		
22.2	Prep Sink Vegetable Wash Faucet	T&S	B-0730	1	KES	GC			●		GC To Provide Connection For Chemical Dispensing Equipment
22.3	Prep Sink Drain Assembly	T&S	B-3950	1	KES	KES; GC				●	
23	4 Shelves - 120in Prep Sink	Amco	CHPPS120	1	KES	KES					Mount Bottom Of Standard At 50" AFF. Provide Plywood Blocking To Mount To Wall.
23A	2 Shelves - 30in	Amco	Custom	1	KES	KES					Mount Bottom Of Standard At 50" AFF. Provide Plywood Blocking To Mount To Wall.
24.3	Hand Sink Wall Mounted - Splash Both	Universal Stainless	EHS-1RL-NF	4	KES	GC				●	Provide Plywood Blocking To Mount To Wall
24.5	Kitchen Hand Sink Faucet Splash Mount	T&S	B-1146-04-CR-VF10	4	KES	GC			●		Provided with B-0199-06-F10, 1.0 GPM Aerator
25	Rice Prep Table Island 66x34	Nationwide Fabrication; Marlo Mfg	Custom Table 66x34in	1	KES	KES					
26	Hot Holding Cabinet - Double Door (Rice)	Food Warming Equipment (FWE)	HLC-1220-8-8-CHP	1	KES	KES	●				
29.2	Dish Sink Add-A-Faucet w/ Pre-Rinse	T&S	B-1033-12CRBSJK Substitute Sprayer B-0107-J-SWV	1	KES	GC			●		
29.3	Dish Sink Drain Assembly	T&S	B-3950	3	KES	KES; GC				●	
29.4	Dish Sink Chemical Faucet	T&S	B-2345-01-XX	1	KES	GC			●		GC To Provide Connection For Chemical Dispensing Equipment
29B	3 Comp Sink - 18x24in Bowls - 111 3/4in	Nationwide Fabrication; Marlo Mfg	S3-30x111.75x36.5-FF	1	KES	GC				●	
30	Shelving System - 3 Comp Sink	Amco	WST1879S	1	KES	KES					Mount bottom of Standard At 56"AFF. Provide Plywood Blocking
30.2	Shelving System - Dish Table	Amco	WST1879S	2	KES	KES					Mount bottom of Standard At 56"AFF. Provide Plywood Blocking. Mount Tight To Dish Machine
31.7	Drying Racks 21x48x85in - With Vented Aluminum Covers	Amco	Custom	1	KES	KES					Mount Bottom Of Standard At 12" AFF. Provide Plywood Blocking To Mount To Wall
32.1A	Ice Maker - Remote Condenser	Hoshizaki	URC-5F	1	KES	KES	●				Condensing Units To Be Secured To The Roof Per Code By GC
32.1B	Ice Maker - Remote Condenser	Hoshizaki	URC-9F	1	KES	KES	●				Condensing Units To Be Secured To The Roof Per Code By GC
32.2A	Ice Maker - Storage Bin	Hoshizaki	B500SF	1	KES	KES				●	
32.3	Icemaker- Filter	Varies	Varies	3	KES	KES			●		
32.4	Ice Maker - Scale Inhibitor	Varies	Varies	3	KES	KES			●		
32.5	Ice Maker - Sanitizer	RGF	IMSB	3	TUV	GC	●				Refer To Installation Guide. When Installed At Utensil Counter, Mount Below Counter In Accessible Location. Refer To Plumbing Drawings.
32A	Ice Maker For B.O.H. Ice Bin (Shorter)	Hoshizaki	KML-700MRJZ	1	KES	KES	●		●		Drain Ice Maker to Floor Sink, RE: Mech. Refrigeration By Tenant.
32C	Ice Maker Mounted On Soda Machine - Air Cooled	Hoshisaki	KMD-530MAJ	1	KES	KES	●		●	●	Drain Ice Maker to Floor Sink, RE: Mech. Refrigeration By Tenant.
32D	Ice Maker Mounted On Soda Machine - Remote Air Cooled	Hoshisaki	KMD-530MRJZ	1	KES	KES	●		●	●	Drain Ice Maker to Floor Sink, RE: Mech. Refrigeration By Tenant.
33	Walk In Cooler 9x12x9 -6ft 3in - Standard	Manitowoc	KAMC46-141-1EC-PCL-4	1	WCs	GC	●			●	Refer To Plumbing and Mechanical Drawings; Refrigeration By Tenant; Remote Exterior Compressor Unit To Be Secured To Roof Per Code By GC
34	Walk-In Cooler Shelving System - 9x12x10	Cambro (Camshelving)	CHP912ER	1	KES	KES					
35.4	Dry Storage Racks 23x192x85in	Varies	Custom	1	KES	KES					Mount Bottom Of Standard At 12" AFF. Provide Plywood Blocking To Mount To Wall.
37	Mop Sink Faucet	T&S	B-0660-BSTR	1	KES	GC			●		
37.1	Mop Sink Chemical Faucet	T&S	B-2345-01-XX	1	KES	GC			●		GC To Provide Connection For Chemical Dispensing Equipment
38	6 Shelves - Chemical Storage Rack	Amco	CHPCS85	1	KES	KES					Mount Bottom Of Standard At 12" AFF. Provide Plywood Blocking To Mount To Wall.
39B	DML 2.0 130in -- Right -- W/POS & Cash Drawer	Franke/Delfield	DML 2.0_RT-130x39	1	KES	KES	●			●	
39B.1	DML 2.0 Wall Trim Package	Franke/Delfield	DML 2.0 Trim Kit	1	KES	KES					
40D	Holding Shelf	Trimark	TGS-39X20X80-B	1	KES	KES	●				
40E	M4.5 - Filler Stand At Range	Select Stainless	Custom	1	KES	KES					
41.5	DML 2.0 Shelving - 130in - Top Shelf	Franke/Delfield	CH000A32	1	KES	KES					Mount Bottom Of Shelf At 74 1/2" AFF. Provide Plywood Blocking To Mount To Wall.
41.6	DML 2.0 Shelving - 130in - Bottom Shelf	Franke/Delfield	CH000A34	1	KES	KES					Mount Bottom Of Lowest Portion Of Shelf At 54 1/2" AFF. Provide Plywood Blocking To Mount To Wall.
42	Shelving System Under Counter Beverage Station	ISS	WST1810CLR	1	KES	KES					Mounted on (4) casters, All casters to be swivel type, Front (2) casters to have brake, Located under utensil counter
43	Beverage Cooler Backbar 36in	Glasstender	LP36X-SS(X)	1	KES	KES	●				
50	Food Processor	Sammic	CA-31	1	KES	KES					
55	Filler Table - 24x34in	Trimark	TS-24x34x36-US-C	1	KES	KES					
56	Beverage Table - Chipotlane	Trimark	TS-36x92.5x36	1	KES	GC	●			●	
61B	Dish Machine (w/Pump)	Hobart	AM16SCB	1	KES	KES	●		●	●	
62B	Dish Table 30x30	Babington Technology	CDT-30X30X36.5-B-L	1	KES	GC					
65	Utility Cart (Not Shown)	Select Stainless	30SU-22-14-C4-TUBS-CUSTOM	1	KES	GC					Provided As Part Of The WIC Shelving
66A	Drop-Off Table - 29x30in	Trimark	TS-29X30x31-US-C	1	KES	KES					
67	Refrigerated Counter Case, Self-Serve	Structural Concepts	CO3324R-UC	1	KES	KES					
69B	M4.0 - Simplicity Bubblers Mini-Quad	Crathco	CS-4E-16	1	KES	GC	●			●	
70	Speed Fill Faucet	T&S	B-0432 MOD	1	KES	GC			●		
71	Quesadilla Press	Turbochef	Sota Touch	1	KES	KES	●				
73A	50" TurboChef Table	Trimark	50X36X36	1	KES	KES					
74	Shelving - Under Counter - 12x36x29in	Metro	Custom	1	KES	KES					

MISC. EQUIPMENT LIST

TAG	DESCRIPTION	QTY	FURNISHED BY	INSTALLE D BY	ELEC	GAS	WATER	SEWER	REMARKS
1	Point of Sale Display	1	TMS	GC					Installed at POS Station
2	Point-Of-Sale System	2	T	TCC					Coordinate Requirements With Tenant and Elec. Drawings
4A	B-Rate (Standard Safe)	1	TS	GC					Install in Office, Bolt to Office Floor Slab
4C	Smart Safe	1	TSS	TSS	●				To Be Installed On Curb Under Serveline, Bolt to Curb Under Serveline POS
5B	Soda Dispenser - With Air-Cooled Ice Maker	1	SPS	SPS	●			●	Drain to Floor Sink, Tenant Millwork Supplier to Provide (2) Adjustable Legs to Support Dispenser From Under The Utensil Counter
5C	Soda Dispenser - With Remote Air-Cooled Ice Maker	1	SPS	SPS	●			●	Drain to Floor Sink, Tenant Millwork Supplier to Provide (2) Adjustable Legs to Support Dispenser From Under The Utensil Counter
6	Soda System Syrup Rack with Carbonator on Stainless Steel Shelf	1	SPS	SPS	●		●		
7A	Bulk CO2 Tank	1	CO2	CO2	●				GC To Secure Cylinders To Wall With Grade 30 Galvanized Steel Chain At 2/3 The Height Of The Cylinder. Attach To Wall With Stainless Steel Quick Link And Screw Eye.
8A	Gas Tankless Water Heater	2	GC	GC		●	●	●	Drain Water Heater To Floor Drain, RE: Mech.
9	Mop Sink, See Plumbing Drawings	1	GC	GC			●	●	See Plumbing Drawings
10	Touch-Free Soap Dispenser	4	WA	GC					
10.1	Hand Sanitizer Dispenser	5	WA	GC					
10.2	Hand Sanitizer Stand	1	WA	GC					
11	Paper Towel Dispenser, Bobrick B262	4	WA	GC					Provide Plywood Blocking to Mount to Wall
12	First Aid Kit	1	T	GC					Confirm Location With Chipotle CM Prior To Installation
13C	M4.0 - Artwork Panel - Carved Rice Board	1	TAS	GC					Provide Plywood Blocking to Mount to Wall
14	License Frame	1	T	GC					Provide Plywood Backing In Wall At License Frame Location, Refer To Arch. Floor Plans And Elevations For License Frame Location.
16A	Fire Extinguisher Type ABC - B456	2	GC	GC					Mount in locations specified by the Fire Marshal. Provide plywood backing at specified locations.
16B	Fire Extinguisher Type K	1	GC	GC					Mount in locations specified by the Fire Marshal. Provide plywood backing at specified locations.
17	Window Shades	2	WS	WS					See Sheet A130 For Location & Size (When Used)
19	Hat & Coat Strips (Not Shown)	1	WA	GC					Provide Plywood Blocking to Mount to Wall
20	2-Drawer File Cabinet, By Tenant	1	T	T					By Tenant
22	Water Softener	1	KES	GC			●	●	See MEP Sheets For Details
23	Backflow Preventer	1	GC	GC			●	●	See MEP Sheets For Details
24	iPAD Wall Station	2	T	GC	●				Tablet By Tenant, Refer to Electrical Drawings
28	Mop Strip (Not Shown)	1	T	GC					Provide Plywood Backing To Mount To Wall, 2 Hole At Mop Basin and 6 Hole In Kitchen
31A	21inx31in Menu System	1	TMB	GC					
32	CO2 Alarm	1	CO2AS	GC	●				Mount At 18" AFF, Refer to Electrical Drawings for Additional Details
33A	M4.0 - Pick-Up Sign - Single Faced - Flush Mounted - Face	1	TSV	GC					

FURNITURE LIST

TAG	DESCRIPTION	QTY	FURNISHED BY	INSTALLED BY	ELEC	GAS	WATER	SEWER	REMARKS
1E	M4.0 - Table 24x24in - Rectangular Base	2	TMS	GC					
1F	M4.0 - Table 24x42in, Rectangular Base (Accessible)	4	TMS	GC					See Detail On A130
1H	M4.0 - Community Table - Low - Window - Length Varies	2	TMS	GC					
2G.1	M4.0 - Bar Height Table 8-Top, With Footrest	2	TMS	GC					One Coat Hook Per Two Seats, Confirm Mounting Location With Shop Drawings
3C.1	M4.0 - Dining Room Chair	17	TMS	GC					
3D	M4.0 - Marshmallow Stool - Fixed	7	TMS	GC					Align Seat With Seam Perpendicular To Table Edge
3E	M4.0 - Bar Stool - Fixed	16	TMS	GC					Align Seat With Seam Perpendicular To Table Edge
4P.1	Banquette Bench (Black) - Floor Mount	2	TMS	GC					
6C	M4.0 - Beverage Counter - With Trash - 4" Splash - 149"	1	TMS	GC				●	Coordinate Floor Drain Installation with Utensil Counter Installation, Bins Provided by Tundra in Smallwares Package
10	Child's High Chair	1	T	GC					
11	Office Chair, By Tenant	1	T	T					By Tenant
12	Patio Chair - Bistro	20	KES	GC					Provided by EMU America, Contact: Carol Hughes (303-744-3200)
13A	24in Round Bistro Table	1	KES	GC					Provided by EMU America, Contact: Carol Hughes (303-744-3200)
13B	30in Square Bistro Table	4	KES	GC					Provided by EMU America, Contact: Carol Hughes (303-744-3200)
14A	3 Bin Trash/Recycling Surround - Exterior	1	TMS	GC					Bins Provided by Tundra in Smallwares Package
14C	M4.0 - 3 Bin Trash/Recycling Surround - Interior	1	TMS	GC					Bins Provided by Tundra in Smallwares Package
15	Patio Umbrella	2	KES	GC					
16	Accessible Patio Table	1	KES	GC					Provided By EMU America, Contact: Carol Hughes (303-744-3200)
17A.2	MOPUS Shelving - 44"	1	TMS	GC					GC To Provide Blocking In Walls At The Ends Of The MOPUS Shelf To Secure Shelves, Wood Edge Of The Shelves To Face The Dining Room



CLIENT:




CHIPOTLE MEXICAN GRILL, INC.
PO BOX 182966
COLUMBUS, OH 43218-2966
TELEPHONE: (614) 318-2682
INTERNET: WWW.CHIPOTLE.COM

COPYRIGHT 2024
THIS DRAWING IS AN INSTRUMENT OF SERVICE AND AS SUCH REMAINS THE PROPERTY OF CHIPOTLE MEXICAN GRILL, INC.. PERMISSION FOR USE OF THIS DOCUMENT IS LIMITED AND CAN BE EXTENDED ONLY BY WRITTEN AGREEMENT WITH CHIPOTLE MEXICAN GRILL, INC..

PROJECT INFORMATION:

STORE NO.: 4757
"ANDERSON IN"
S SCATTERFIELD RD & 59TH STREET
ANDERSON, IN 46013

SEAL:

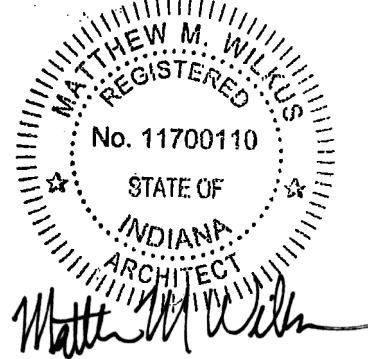

July 25, 2024

MATTHEW M. WILKUS
LICENSE #AR11700110
(EXPIRES 12/31/2024)

PROJECT NO. 2022-0494

DRAWN BY RDB

CHECKED BY

ISSUE RECORD:

12/12/2023

06/19/2024

07/24/2024

PERMIT SET

BID SET

CONSTRUCTION SET

REVISIONS:

1 05/20/2024


DB UPDATES

TITLE:

FF&E SCHEDULES

SHEET NUMBER:


A131

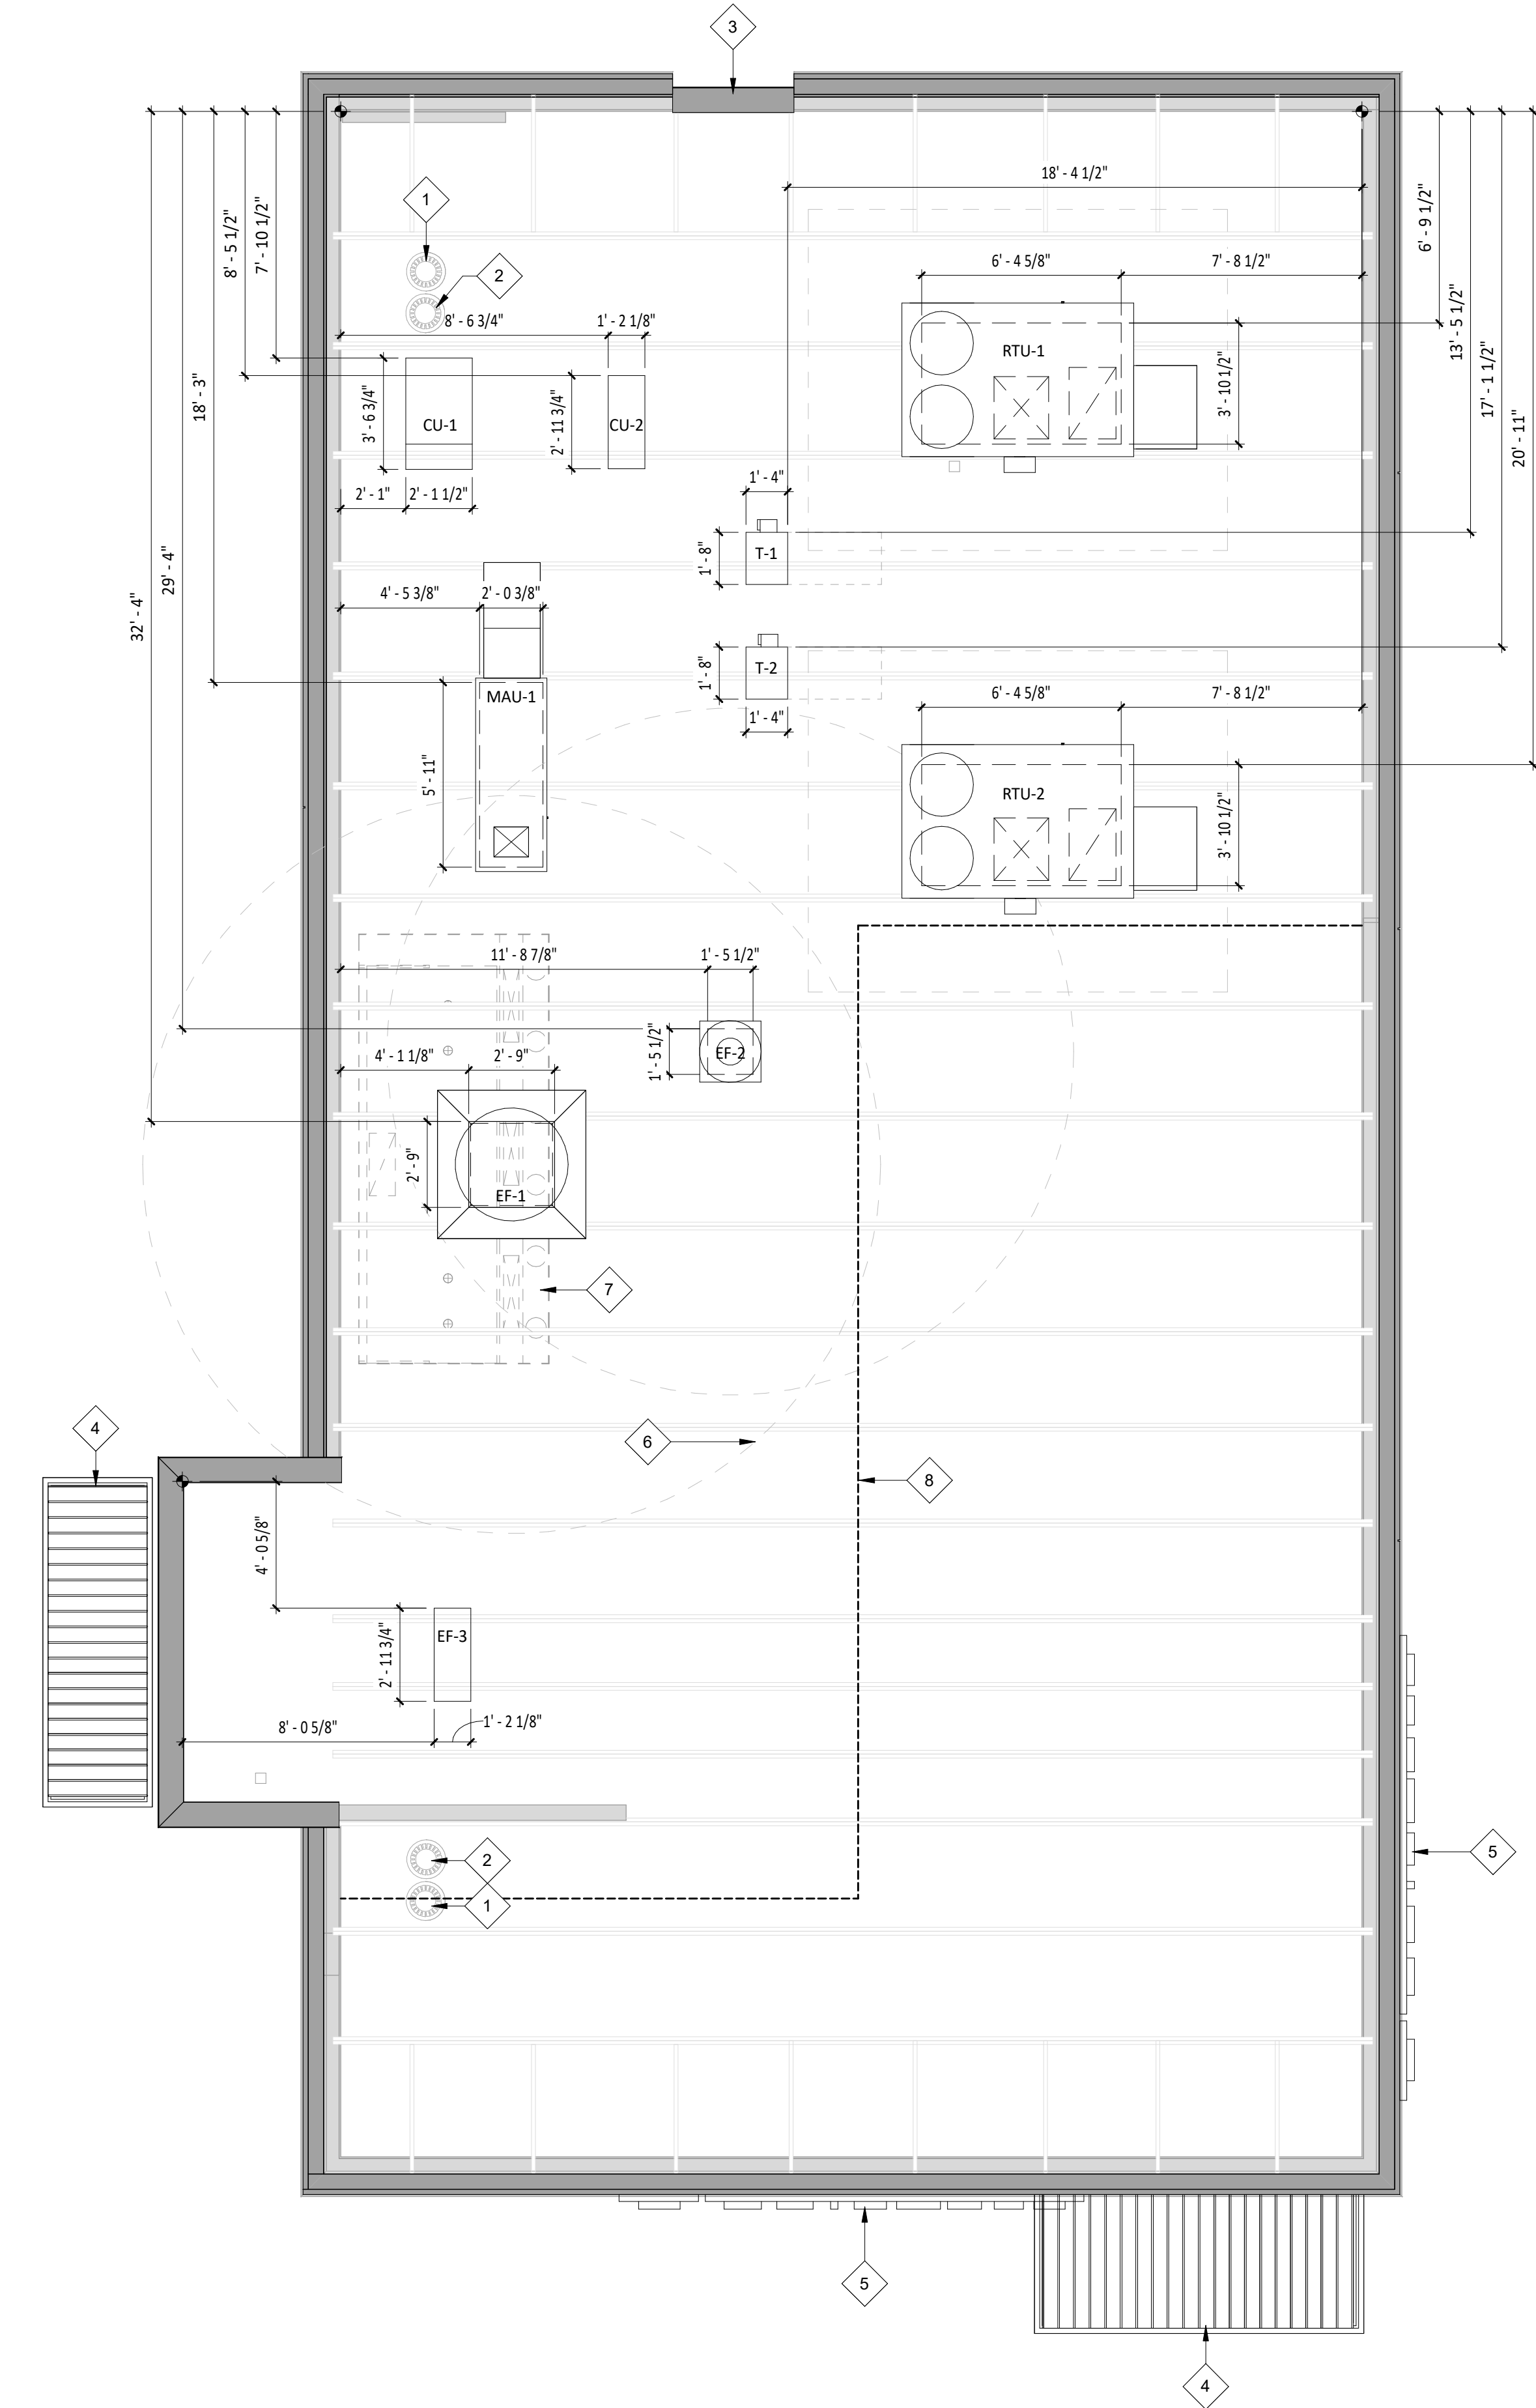

1 ROOF PLAN
SCALE: 1/4" = 1'-0"

HVAC EQUIPMENT

DESCRIPTION	FURNISHED BY	INSTALLED BY	ELEC	UTILITY			REMARKS
				GAS	WATER	SEWER	
Exhaust Fans & Curbs	HS	GC	•				Curb furnished by HS, installed by GC
Make Up Air Unit & Curbs	HS	GC	•				Curb furnished by HS, installed by GC
Roof Top Units & Curbs	HES	GC	•	•	•	•	Curb furnished by HS, installed by GC
Test & Balance System	TAB	-					Furnish HVAC Test & Balance per Tenant's National Account Program.

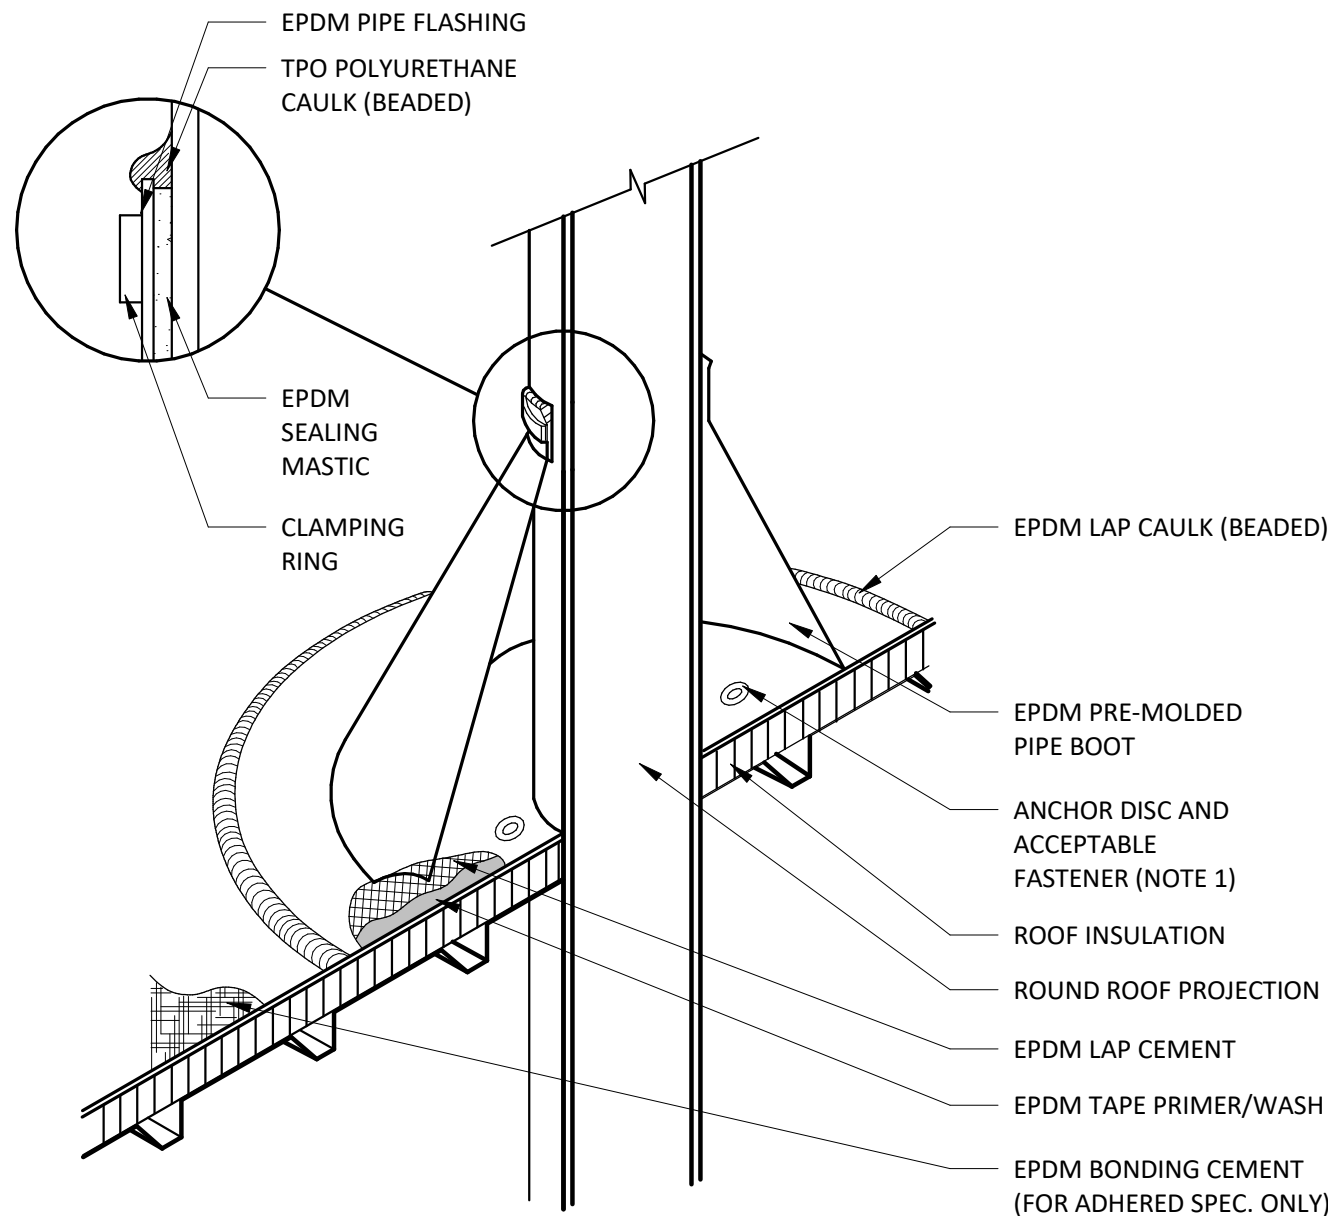


NOTE:

- WITH MECHANICALLY FASTENED OR BALLASTED SPECIFICATIONS, MEMBRANE MUST BE MECHANICALLY ATTACHED WITH 2" (50 mm) ANCHOR DISC AND ACCEPTABLE FASTENERS (MINIMUM OF 4 PER PIPE).
- DO NOT OVERLAP THE FLANGES FROM ADJACENT PIPE FLASHINGS.
- ANY SEAM UNDER BOOT FLANGE TO BE TREATED AS T-JOINT.
- BOTH SURFACES TO BE MATED MUST BE CLEANED WITH TAPE PRIMER/WASH. EPDM TAPE PRIMER/WASH MUST BE COMPLETELY DRY AND TACK FREE BEFORE APPLYING EPDM LAP CEMENT.

2 BOOT DETAIL

SCALE: 1/2" = 1'-0"

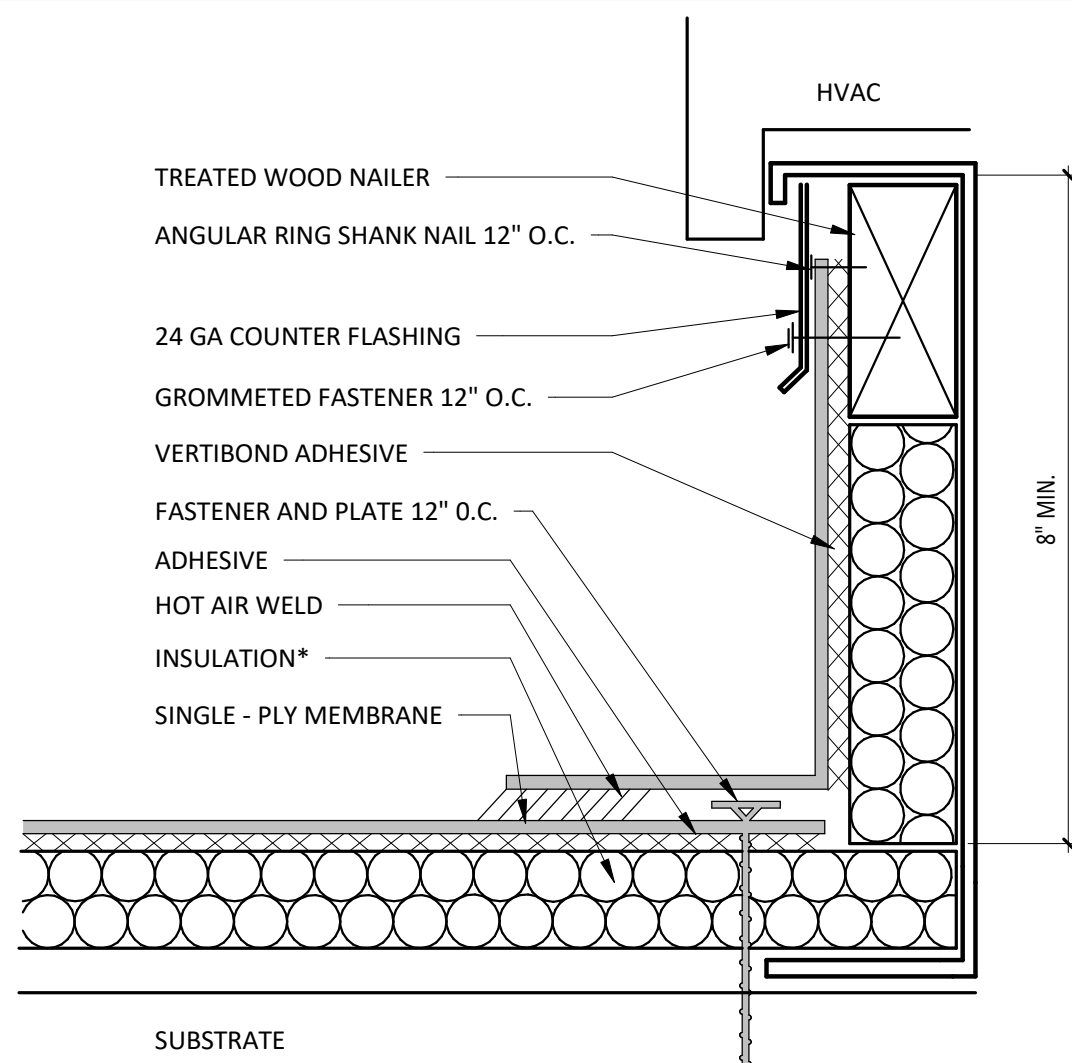

NOTES:

- INSTALLATION TO BE COMPLETED IN ACCORDANCE WITH MANUFACTURERS SPECIFICATIONS.
- DO NOT SCALE DRAWINGS.
- USE PREFABRICATED OUTSIDE CORNERS.
- INSULATION MUST BE SECURELY FASTENED.
- *GLASS - FACED POLYISO INSULATION IS OPTIONAL AND MAY NOT BE REQUIRED ON EVERY PROJECT. IF INSULATION IS NOT REQUIRED, THE MEMBRANE MUST BE ADHERED TO AN APPROVED SURFACE.

3 CURB FLASHING

SCALE: 1/2" = 1'-0"

GENERAL NOTES - ROOF PLAN

- SEE STRUCTURAL DRAWINGS FOR LOCATIONS AND SIZE OF STRUCTURAL ROOF REINFORCEMENTS.
- SEE MECHANICAL PLANS FOR ROOF TOP EQUIPMENT.
- COORDINATE ALL ROOF PENETRATIONS, FLASHING, AND REPAIR W/ CHIPOTLE CONSTRUCTION MANAGER PRIOR TO COMMENCEMENT OF WORK.
- DIMENSIONS FOR ROOF TOP EQUIPMENT WITH CURBS IS TO THE OUTSIDE FACE OF CURB. DIMENSIONS FOR EQUIPMENT WITHOUT CURBS ARE TO THE CENTER OF THE UNIT. ALL DIMENSIONS ARE FOR REFERENCE ONLY. ROOFING CONTRACTOR TO ADJUST AS NECESSARY IN FIELD. CONTACT ENGINEERING CONSULTANTS FOR ANY MAJOR MODIFICATIONS TO LAYOUT.
- JOISTS FOR SHELL BUILDING WERE DESIGNED FOR THE RTU WEIGHTS AND PLACEMENT EXHIBITED. IF LOCATION OR ORIENTATION OF A UNIT MUST CHANGE, NOTIFY ARCHITECT IMMEDIATELY.
- SEE M700 FOR PENETRATION DETAILS AT RTUS AND THE EXHAUST FAN.
- PROVIDE INSULATED CURBS FOR ALL EQUIPMENT IN EXPOSED DECK AREA ONLY.
- ALL UNUSED ROOFTOP EQUIPMENT TO BE REMOVED. PATCH ROOF AS NECESSARY.
- PROVIDE TAPERED INSULATED CRICKET AT ALL EQUIPMENT CURBS.
- LOCATE ALL UNITS SO DUCT DROPS BETWEEN TRUSS JOISTS. NOTIFY ARCHITECT IMMEDIATELY IF ANY UNITS NEED TO SHIFT FROM PLAN LOCATION SHOWN.

KEYNOTE LEGEND

- | | |
|---|---|
| 1 | PRIMARY ROOF DRAIN LOCATION - GENERAL CONTRACTOR IS RESPONSIBLE OF SNAKE CLEANING PRIOR TO BUILDING TURNOVER. |
| 2 | OVERFLOW ROOF DRAIN LOCATION - GENERAL CONTRACTOR IS RESPONSIBLE OF SNAKE CLEANING PRIOR TO BUILDING TURNOVER. |
| 3 | EXISTING ROOF LADDER LOCATION. |
| 4 | CANOPY BELOW - REFER TO EXTERIOR ELEVATIONS. |
| 5 | SIGNAGE BY TENANTS VENDOR - GENERAL CONTRACTOR TO PATCH AND REPAIR ADJACENT WALL AS REQUIRED FOR SIGN INSTALLATION - GENERAL CONTRACTOR TO COORDIANTE SIGNAGE PENETRATIONS WITH SIGNAGE VENDOR. |
| 6 | 10'-0" RADIUS CLEARANCE FOR FRESH AIR INTAKES - REFER TO MECHANICAL DRAWINGS FOR ADDITIONAL INFORMATION. |
| 7 | DASHED LINE INDICATES LOCATION OF HOOD SYSTEM BELOW. |
| 8 | HIDDEN LINE INDICATES SOFFIT LOCATION BELOW IN WHICH TERMINATES TO UNDERSIDE OF EXISTING DECK. |



CLIENT:



CHIPOTLE MEXICAN GRILL, INC.
PO BOX 182566
COLUMBUS, OH 43218-2566
TELEPHONE: (614) 318-2682
INTERNET: WWW.CHIPOTLE.COM

COPYRIGHT 2024
THIS DRAWING IS AN INSTRUMENT OF SERVICE AND AS SUCH REMAINS THE PROPERTY OF CHIPOTLE MEXICAN GRILL, INC. PERMISSION FOR USE OF THIS DOCUMENT IS LIMITED AND CAN BE EXTENDED ONLY BY WRITTEN AGREEMENT WITH CHIPOTLE MEXICAN GRILL, INC.

PROJECT INFORMATION:

STORE NO.: 4757
"ANDERSON IN"
S SCATTERFIELD RD & 59TH STREET
ANDERSON, IN 46013

SEAL:



July 25, 2024

MATTHEW M. WILKUS
LICENSE #AR11700110
(EXPIRES 12/31/2024)

PROJECT NO. 2022-0494

DRAWN BY RDB

CHECKED BY

ISSUE RECORD:

12/12/2023 PERMIT SET

06/19/2024 BID SET

07/24/2024 CONSTRUCTION SET


REVISIONS:

TITLE:

ARCHITECTURAL
ROOF PLAN

SHEET NUMBER:

A140

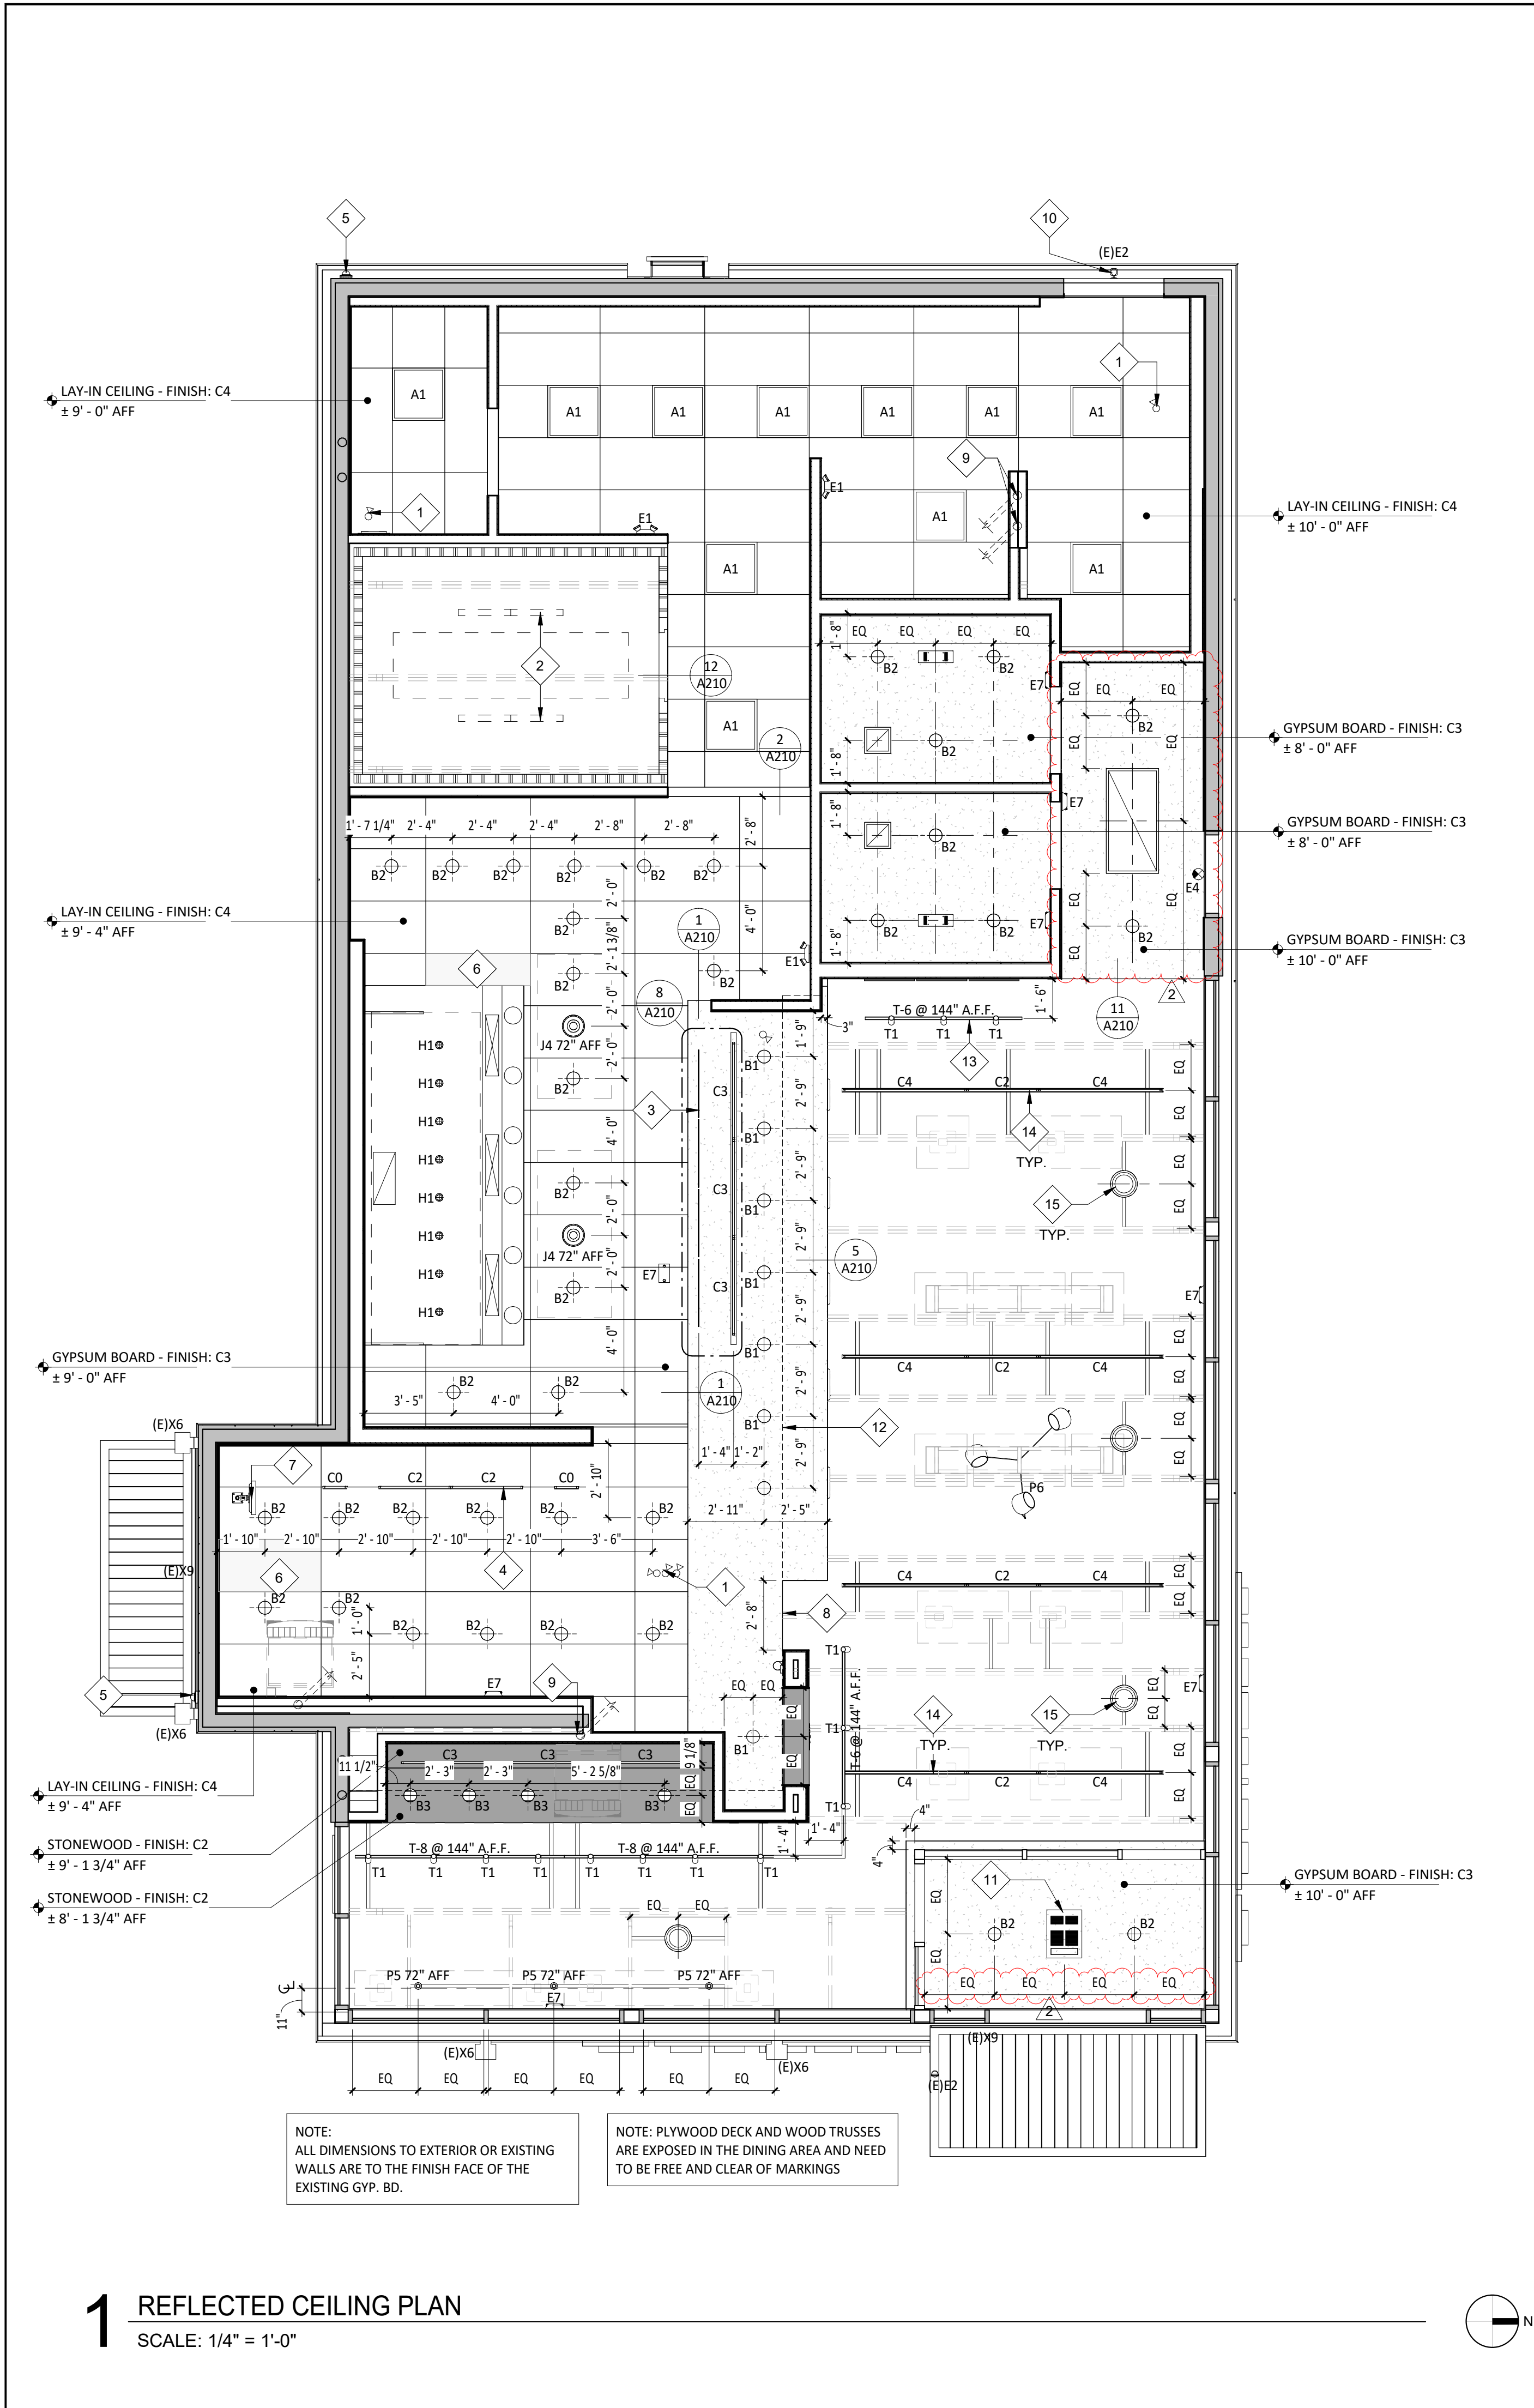

LIGHTING FIXTURE SCHEDULE

ITEM #	MOUNT	DESCRIPTION	REMARKS
EXISTING			
(E)E2	VARIOUS	EMERGENCY LIGHT - SINGLE HEAD	SEE SHEET E100
(E)X6	WALL	WALL PACK BY LANDLORD	SEE SHEET E100
(E)X9	SURFACE	LED CHANNEL LIGHT BY LANDLORD	SEE SHEET E100
NEW			
(E)E2	VARIOUS	EMERGENCY LIGHT - SINGLE HEAD	SEE SHEET E100
(E)X6	WALL	WALL PACK BY LANDLORD	SEE SHEET E100
A1	LAY-IN	2x2 LED LENSED TROFFER	SEE SHEET E100
B1	CEILING	RECESSED 6IN CAN LIGHT	SEE SHEET E100
B2	CEILING	RECESSED 6IN CAN LIGHT	SEE SHEET E100
B3	CEILING	M4.0 - RECESSED 6IN CAN LIGHT (BLACK)	SEE SHEET E100
C0	SURFACE	LOW PROFILE LED 1FT	SEE SHEET E100
C2	SURFACE	LOW PROFILE LED 3FT	SEE SHEET E100
C3	SURFACE	LOW PROFILE LED 4FT	SEE SHEET E100
C4	SURFACE	LOW PROFILE LED 5FT	SEE SHEET E100
E1	VARIOUS	EMERGENCY LIGHT - DUAL HEAD	SEE SHEET E100
E4	VARIOUS	WHITE EXIT LIGHT - STANDARD RED LETTERS	SEE SHEET E100
E7	VARIOUS	EMERGENCY LIGHT - DUAL HEAD	SEE SHEET E100
H1	SURFACE	VAPOR PROOF HOOD LIGHT	SEE SHEET E100
J4	PENDANT	M4.0 - PENDANT LIGHT	SEE SHEET E100
P5	PENDANT	PENDANT LIGHT	SEE SHEET E100
P6	PENDANT	M4.0 - MULTI-PENDANT LIGHT	SEE SHEET E100 & A701
T1	TRACK	TRACK LIGHTING HEAD	SEE SHEET E100
T-6 @ 144" A.F.F.	SUSPENDED	M4.0 - TRACK 6'	SEE SHEET E100
T-8 @ 144" A.F.F.	SUSPENDED	M4.0 - TRACK 8'	SEE SHEET E100

GENERAL NOTES - RCP

- ALL INTERIOR LIGHT FIXTURES AND LAMPS PROVIDED BY TENANT'S LIGHT/LAMP SUPPLIER.
- ALL INTERIOR LIGHT FIXTURES AND LAMPS INSTALLED BY GC. CAREFULLY REVIEW LIGHTING FIXTURE SCHEDULE ON SHEET E100.
- KITCHEN EXHAUST HOOD PROVIDED BY HS AND INSTALLED BY GC. GC TO COORDINATE PRESSURE TEST AND VIRO GUARD WITH ENVIROMATIC, INC.
- ANSUL BOX & FIRE SUPPRESSION SYSTEM PROVIDED BY AND INSTALLED BY HS. HOOD INTERLOCK BY GC. ELECTRICAL CONNECTION BY GC. RE: ELEC.
- MENU BOARD ASSEMBLY PROVIDED BY TMB, INSTALLED BY G.C.
- PROVIDE BLOCKING ABOVE MENU BOARD ASSEMBLY FOR INSTALLATION.
- REFER TO "09900 PAINTING - GENERAL" IN SPECIFICATIONS FOR FINISHES AT EXPOSED CEILING AREAS IN ADDITION TO NOTES LISTED ON THIS SHEET AND A120
- UNISTRUT TO BE LEFT UNPAINTED. PROVIDE MATCHING CLOSER STRIPS AND END CAPS. CLOSER STRIP TO BE APPLIED TO THE UNDERSIDE OF THE UNISTRUT.
- ALL HEIGHTS ARE TO BOTTOM OF FIXTURE UNLESS NOTED OTHERWISE.
- LIGHT DETAILS ARE LOCATED ON SHEET A210. FIXTURE AND LAMP SPECIFICATIONS ARE LOCATED ON E100.
- ALL UNISTRUT SUPPORTING CEILING ELEMENTS AND/ OR DUCT WORK SHALL NOT CONTAIN ANY ELECTRICAL CONDUIT. ALL ELECTRICAL CONDUIT MUST RUN IN SEPARATE UNISTRUT.
- ALL UNISTRUT, CONDUIT, SPRINKLER & WATER LINES SHALL BE INSTALLED TO THE BOTTOM OF THE DECK OR AS SHOWN IN DETAILS & LEFT UNPAINTED.
- ALL DIMENSIONS ARE TO FACE OF FRAMING, OR CENTERLINE OF FIXTURE UNLESS NOTED OTHERWISE.
- SEE ELECTRICAL DRAWINGS FOR SHATTER RESISTANT LAMP LOCATIONS.
- ALL EMERGENCY FIXTURES, LIGHTS AND STROBES SHALL BE ALIGNED OR CENTERED ON WALLS.
- FULL CERAMIC TILE COURSEING SHALL TAKE PRECEDENT OVER ANY CEILING/HEADER DIMENSION INDICATED IN THE PLAN, REFER TO A120.
- ALL CONDUIT AND PIPE PENETRATIONS OF THE SERVING LINE SOFFIT ARE TO BE HELD TIGHT TO THE DECK. PLEASE CONSULT WITH THE CHIPOTLE CM SHOULD ANY CONFLICTS ARISE.
- BATT INSULATION TO BE INSTALLED ABOVE THE RESTROOM CEILING.
- ALL LAY-IN CEILING PENETRATIONS TO BE HELD TIGHT TO WALLS. REFER TO DETAIL ON SHEET A210 AND PLUMBING DRAWINGS FOR DETAILS.
- REFER TO STRUCTURAL DRAWINGS FOR HOOD SUSPENSION DETAILS.
- ALL EXTERIOR BUILDING MOUNTED AND PATIO LIGHT FIXTURES AND LAMPS PROVIDED BY TENANT'S LIGHT/LAMP SUPPLIER, U.N.O.
- ALL EXTERIOR PARKING LOT LIGHT FIXTURES AND LAMPS PROVIDED BY AND INSTALLED BY G.C. CAREFULLY REVIEW LIGHTING FIXTURE SCHEDULE ON SHEET E100.
- ALL EXTERIOR BUILDING MOUNTED AND PATIO LIGHT FIXTURES AND LAMPS INSTALLED BY G.C. CAREFULLY REVIEW LIGHTING FIXTURE SCHEDULE ON SHEET E100.
- SECURITY CAMERA LOCATIONS ARE ONLY APPROXIMATE LOCATIONS. FOR GUIDANCE ON THE SPECIFIC LOCATION/ORIENTATION OF THESE CAMERAS, REFER TO THE ENVISION INSTALLATION GUIDE
- REFER TO A120 FOR FINISH LEGEND.

KEYNOTE LEGEND

1	INTERIOR SECURITY CAMERA LOCATIONS - TYPICAL SIX (6) - CENTER IN CEILING TILE WHERE APPLICABLE.
2	LIGHTING FOR COOLER PROVIDED BY COOLER MANUFACTURER - GENERAL CONTRACTOR TO PROVIDE ROUGH-IN AND FINAL HOOK-UP.
3	LINE OF SUSPENDED MENU BOARD SYSTEM.
4	UNDERSHELF TASK LIGHTING - REFER TO ELECTRICAL SHEETS FOR ADDITIONAL INFORMATION.
5	EXTERIOR SECURITY CAMERA LOCATIONS - TYPICAL OF TWO (2).
6	PROVIDE FREE AND CLEAR ACCESS TO HOOD AS REQUIRED - GENERAL CONTRACTOR TO COORDINATE WITH ALL TRADES TO MAINTAIN.
7	LOCATION OF MONITOR BY TENANTS VENDOR.
8	HOLD SOFFIT FRAMING SO GYPSUM SOFFIT FINISH DOESN'T OVERLAP WALL FINISH ON BOX BELOW - REFER TO FINISH PLAN FOR ADDITIONAL INFORMATION.
9	4" PVC PIPES STUBBED ABOVE CEILING FOR SODA BUNDLE - REFER TO PLUMBING DRAWINGS FOR ADDITIONAL INFORMATION.
10	MOUNT EMERGENCY LIGHT FIXTURE TO BOTTOM OF CANOPY.
11	LOCATION OF CEILING MOUNTED VESTIBULE HEATER - REFER TO ELECTRICAL DRAWINGS FOR ADDITIONAL INFORMATION.
12	FULL HEIGHT SOFFIT WALL TO DECK ABOVE SHOWN DASHED - ALIGN FINISHED FACE WITH BACK WALL OF MOPUS.
13	CENTER TRACK LIGHTING ON ARTWORK.
14	CENTER LIGHT FIXTURES BETWEEN STRUCTURAL MEMBERS.
15	FOUR (4) SPEAKERS - REFER TO SHEET A210 FOR ADDITIONAL INFORMATION.

SECURITY DEVICE SCHEDULE

DESCRIPTION	QTY	FURNISHED BY	INSTALLED BY	ELEC	UTILITIES	REMARKS
SECURITY MONITOR	1	SSS	SSS	•	GAS SEWER WATER	
SECURITY ALARM - MOTION DETECTORS	1	T.B.D.	T.B.D.	•		GC RESPONSIBLE FOR COORDINATING SEQUENCING OF PREWIRING WITH COMPLETION OF INTERIOR FINISHES (GYP. BD. FINISHES)
72 HR SECURITY DVR	1	SSS	SSS	•		
CLOSED CIRCUIT T.V. CAMERA - OUTDOOR	2	SSS	SSS	•		INSTALL AT 9'-6" U.N.O.
CLOSED CIRCUIT T.V. CAMERA - INDOOR	6	SSS	SSS	•		

SPEAKER SCHEDULE

ITEM #	QTY	DESCRIPTION	COLOR/FINISH	MOUNT	REMARKS
SP1	4	DINING ROOM SPEAKER	BLACK	SUSPENDED	REFER TO A201 & E110 FOR DETAILS

CONDUIT GUIDELINES

SEE ELECTRICAL DRAWINGS FOR CONDUIT REQUIREMENTS. METAL CLAD CABLE AND FLEXIBLE METAL CONDUIT SHALL NOT BE INSTALLED IN AREAS EXPOSED TO VIEW UNLESS SPECIFICALLY NOTED OTHERWISE

CLIENT:

CHIPOTLE MEXICAN GRILL, INC.
PO BOX 182966
COLUMBUS, OH 43218-2966
TELEPHONE: (614) 318-2682
INTERNET: WWW.CHIPOTLE.COM

COPYRIGHT 2024
THIS DRAWING IS AN INSTRUMENT OF SERVICE AND AS SUCH REMAINS THE PROPERTY OF CHIPOTLE MEXICAN GRILL, INC. PERMISSION FOR USE OF THIS DOCUMENT IS LIMITED AND CAN BE EXTENDED ONLY BY WRITTEN AGREEMENT WITH CHIPOTLE MEXICAN GRILL, INC.

PROJECT INFORMATION:

STORE NO.: 4757

"ANDERSON IN"

S SCATTERFIELD RD & 59TH STREET

ANDERSON, IN 46013

SEAL:

July 25, 2024

MATTHEW M. WILKUS
LICENSE #AR11700110
(EXPIRES 12/31/2024)


PROJECT NO. 2022-0494
DRAWN BY RDB
CHECKED BY

ISSUE RECORD:
12/12/2023 PERMIT SET
06/19/2024 BID SET
07/24/2024 CONSTRUCTION SET


REVISIONS:
2 07/24/2024 CONSTRUCTION SET

TITLE:
REFLECTED
CEILING PLAN


SHEET NUMBER:
A201

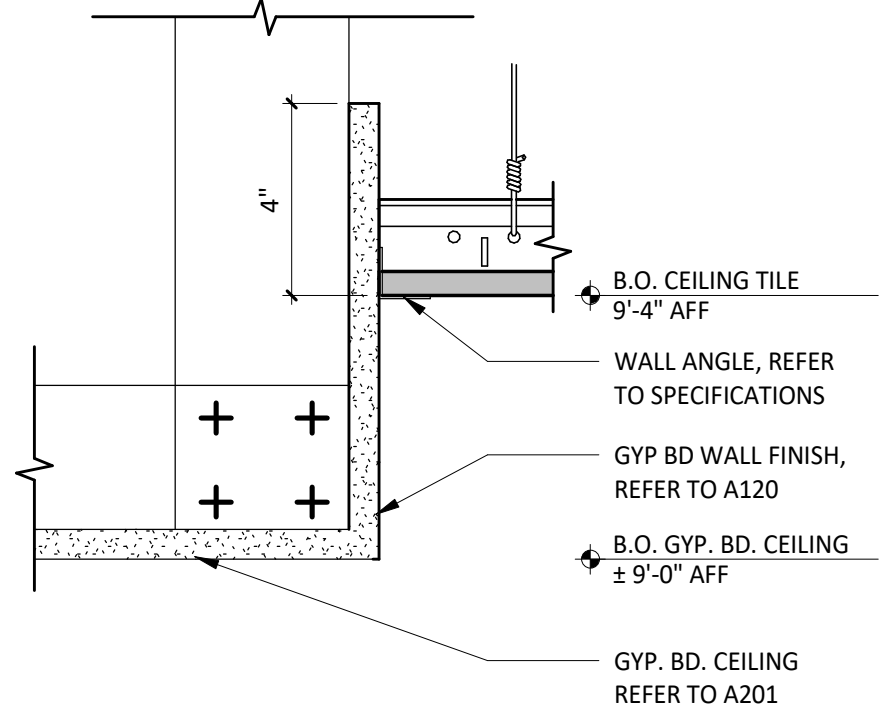


1 KITCHEN CEILING TRANSITION
SCALE: 3" = 1'-0"

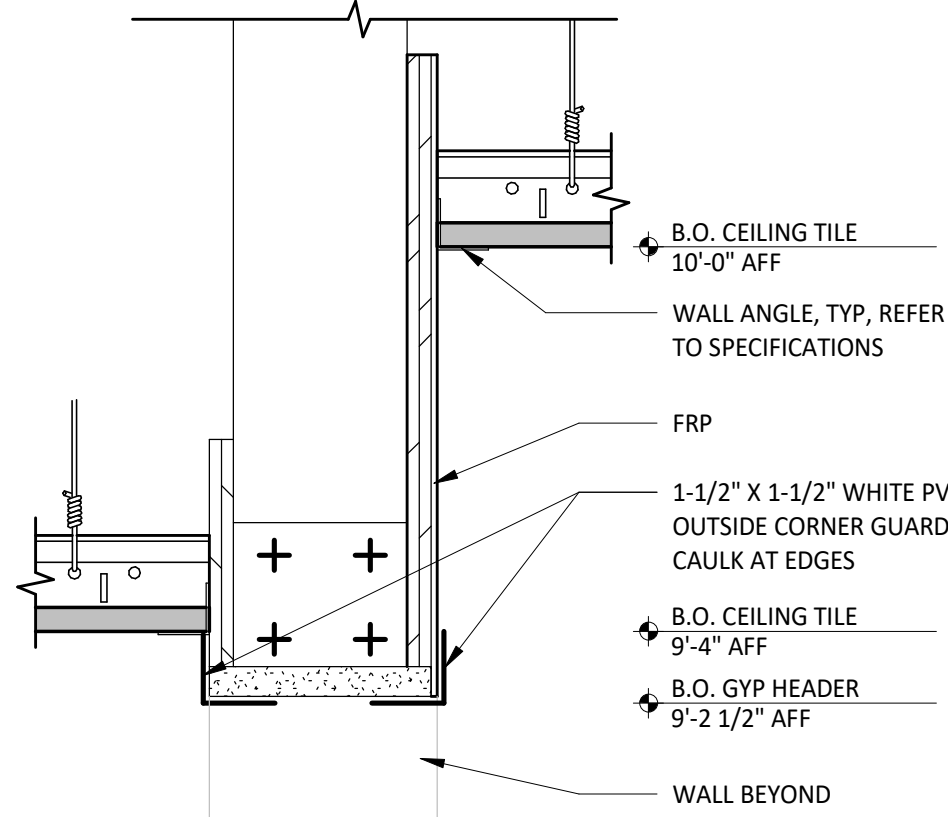


2 KITCHEN CEILING TRANSITION
SCALE: 3" = 1'-0"

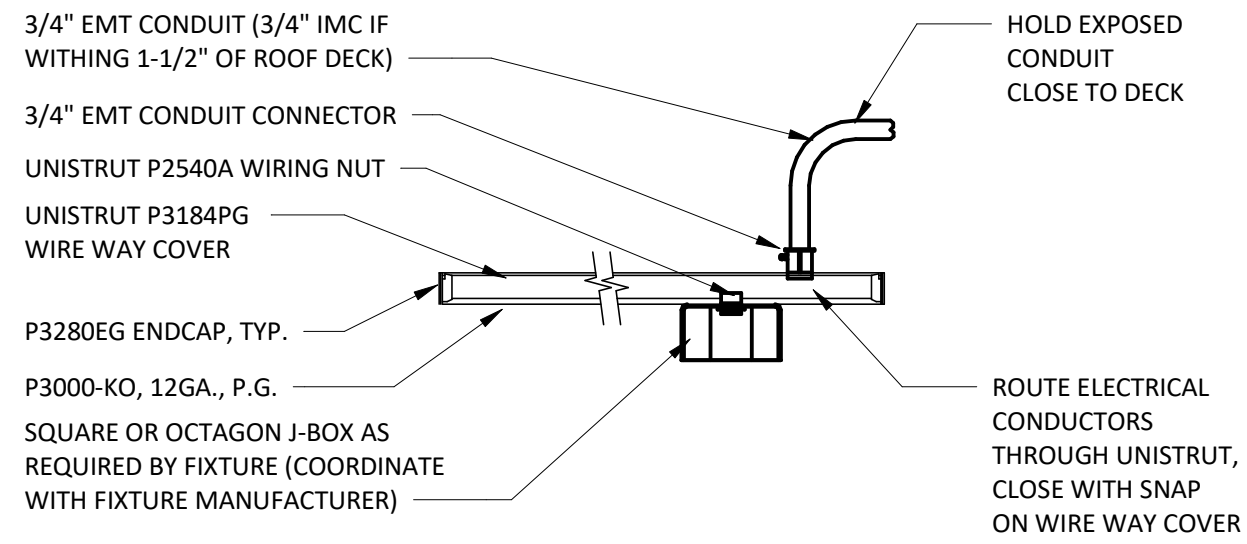


3 UNISTRUT MOUNTING DETAIL
SCALE: 1 1/2" = 1'-0"

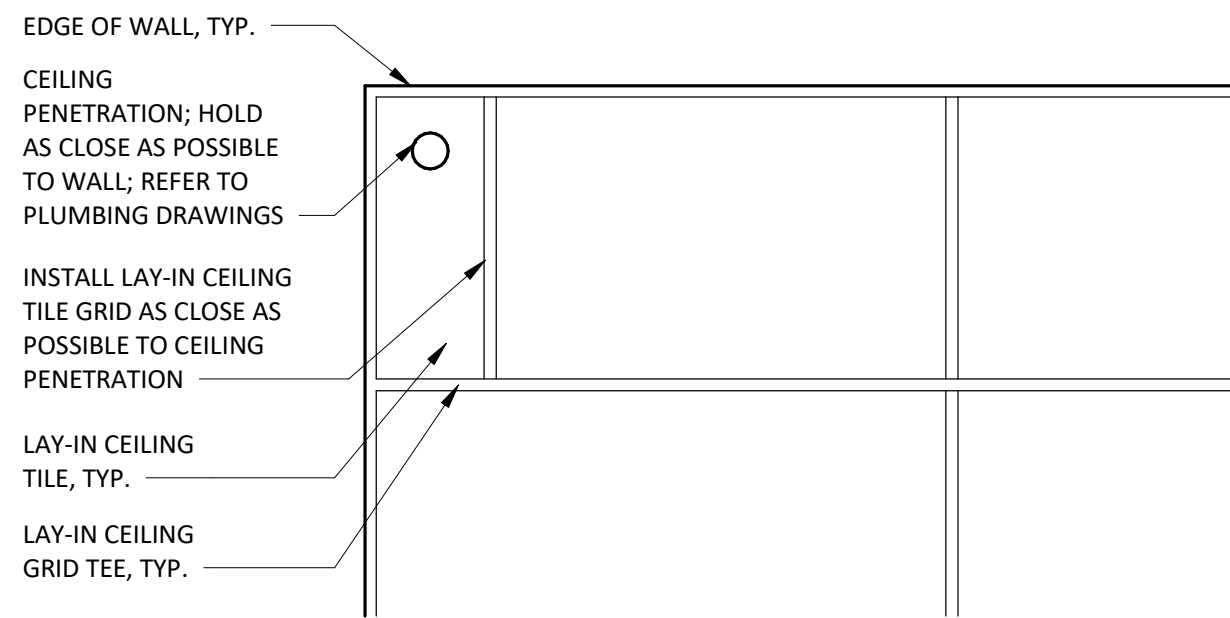


4 LAY-IN CEILING PENETRATION - PLAN DETAIL
SCALE: 3/4" = 1'-0"

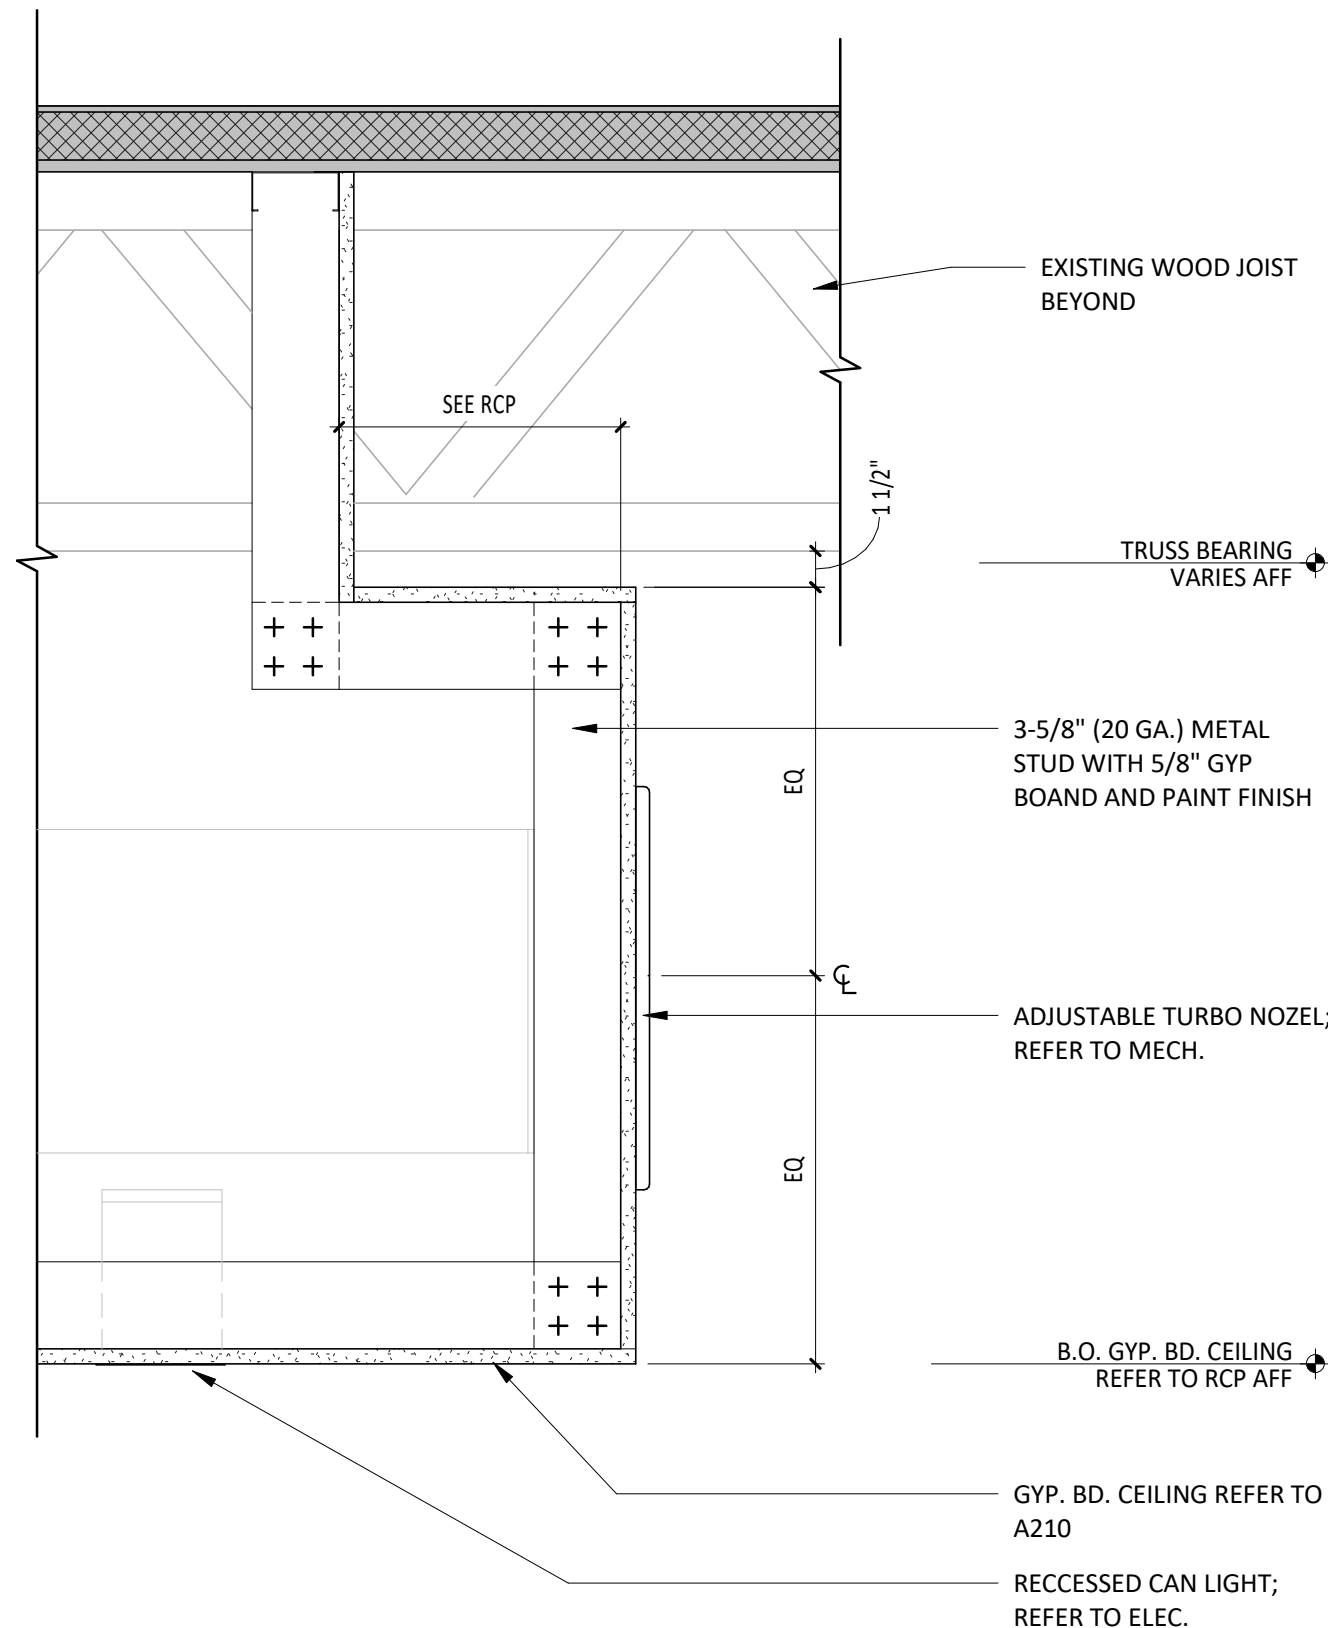


5 SECTION @ JOIST SHELF
SCALE: 1 1/2" = 1'-0"

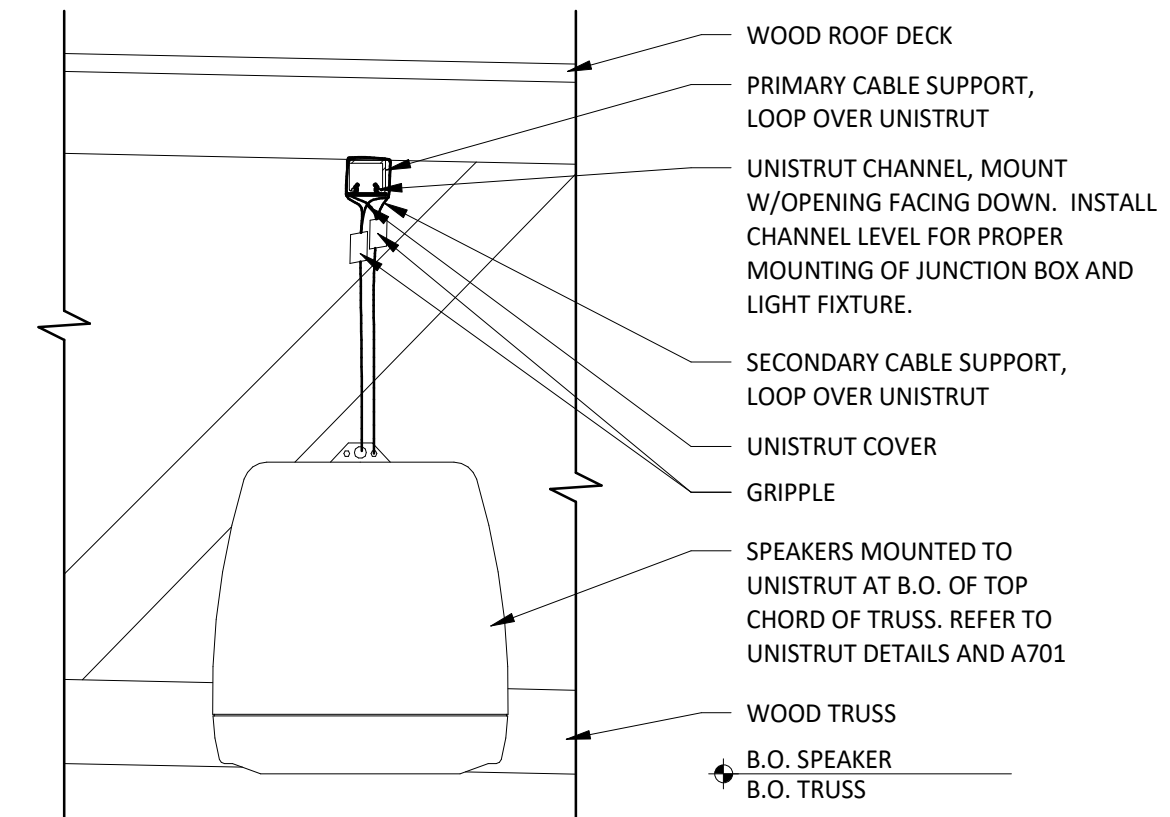


6 SUSPENDED SPEAKER INSTALLATION
SCALE: 1 1/2" = 1'-0"

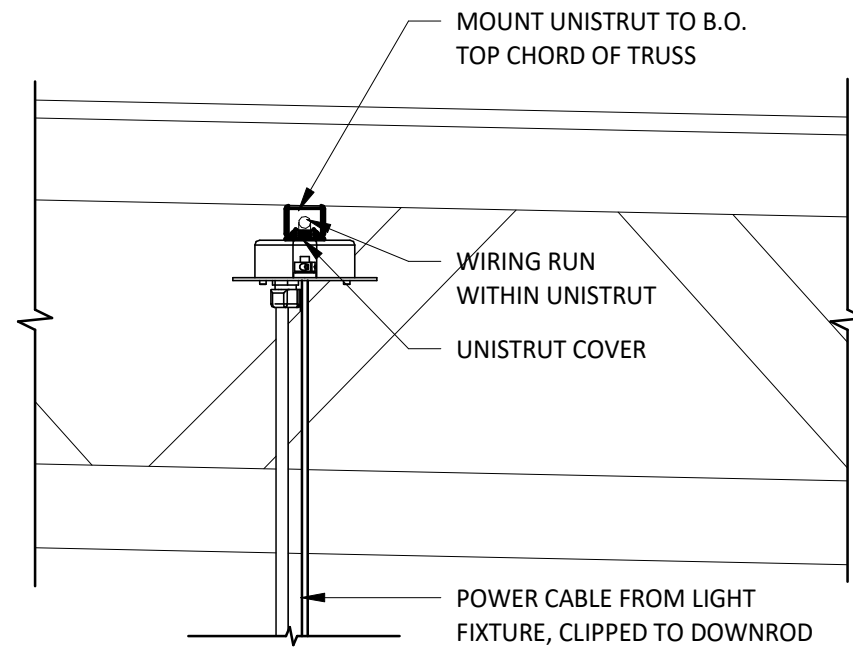


7 TYP. UNISTRUT MOUNTING DETAIL
SCALE: 1 1/2" = 1'-0"

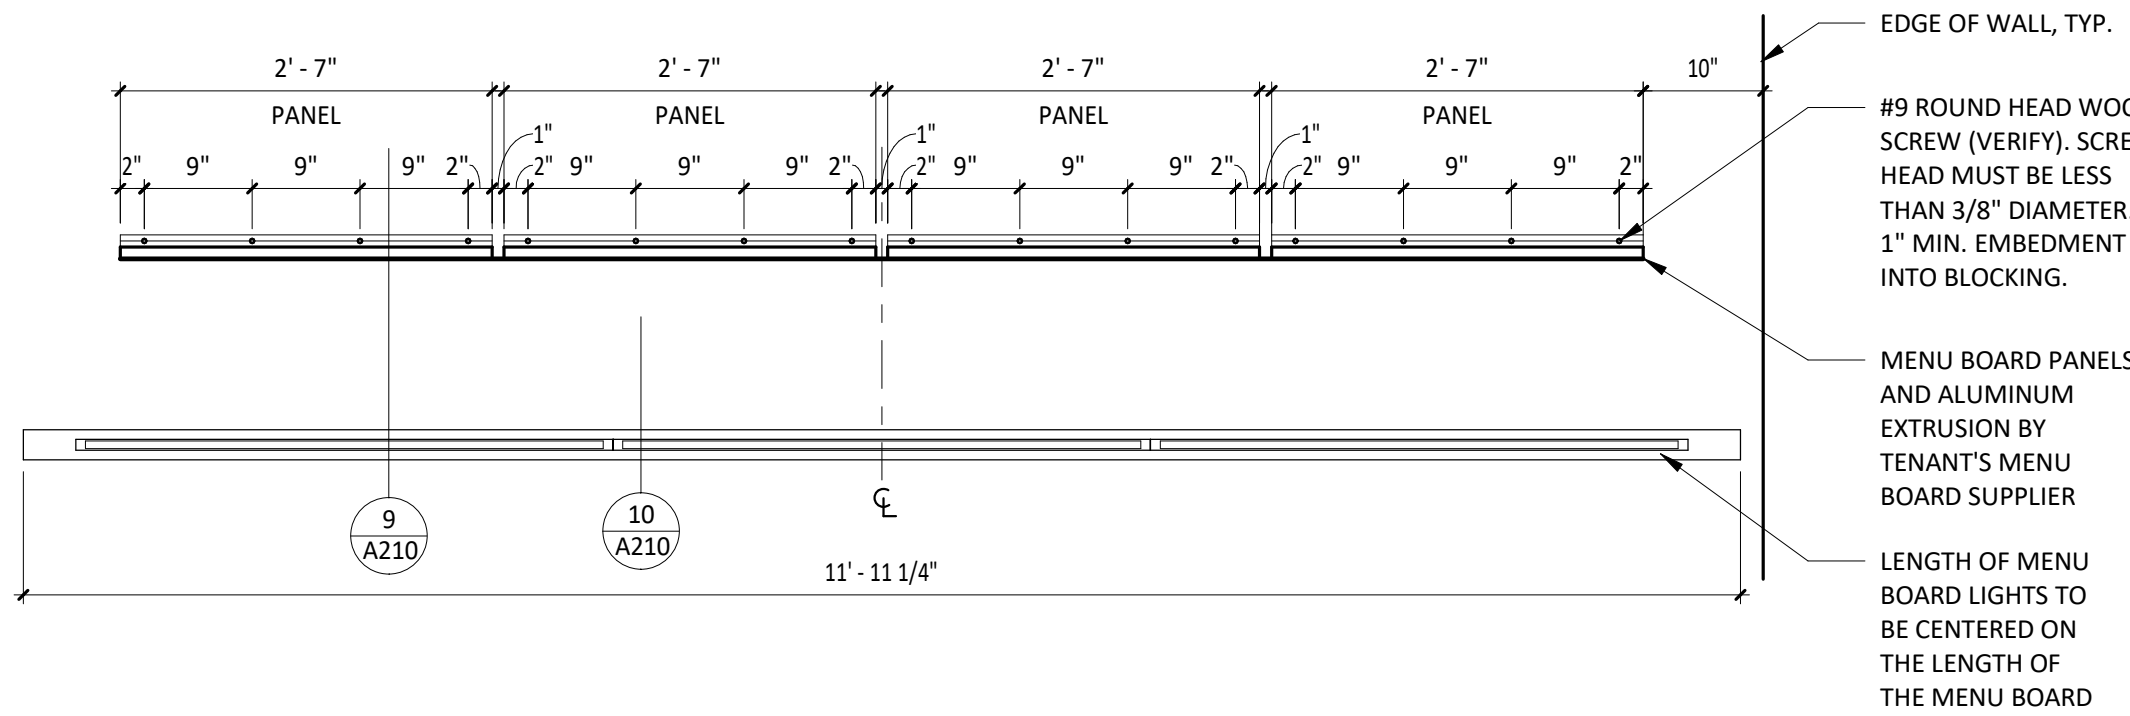


8 MENU - SCREW PATTERN PLAN
SCALE: 3/4" = 1'-0"

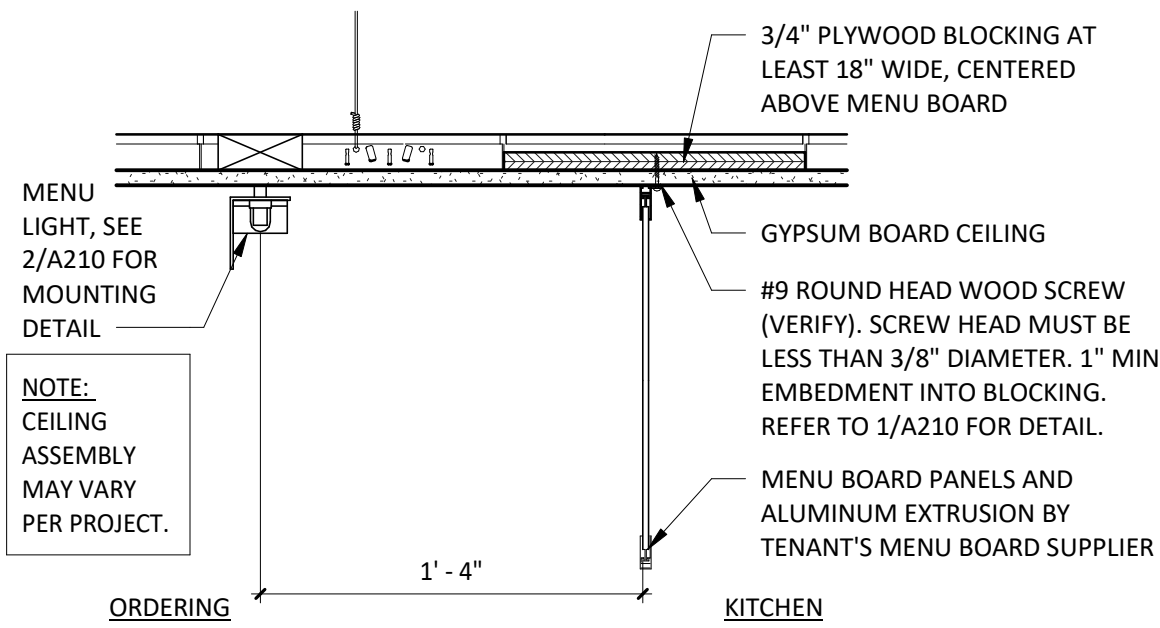


9 MENU BOARD DETAIL
SCALE: 1 1/2" = 1'-0"

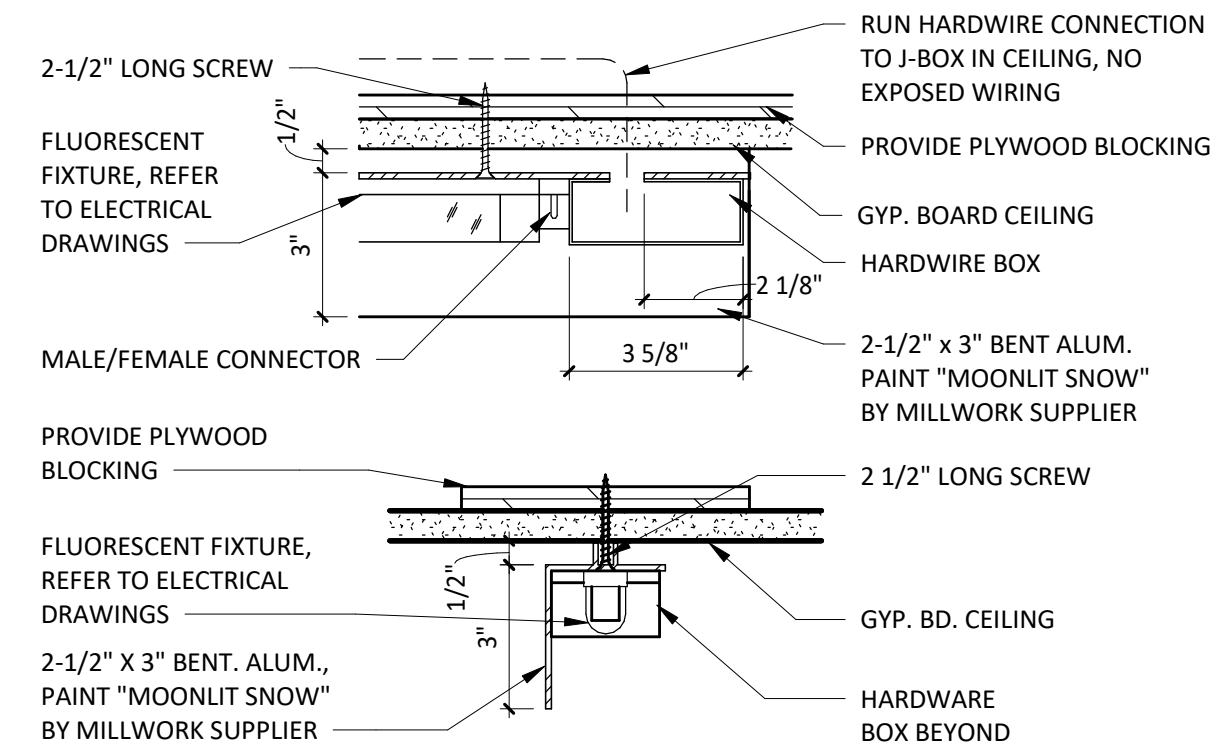


10 MENU BOARD LIGHT DETAIL
SCALE: 3" = 1'-0"

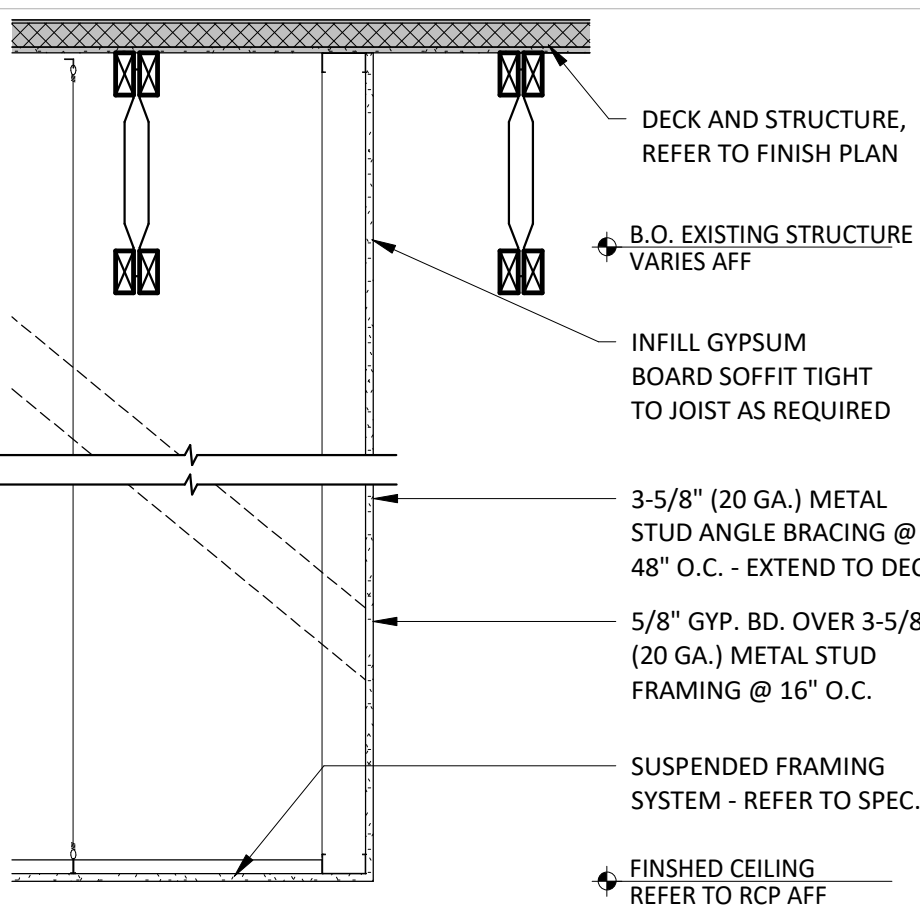

11 SECTION @ SOFFIT
SCALE: 3/4" = 1'-0"

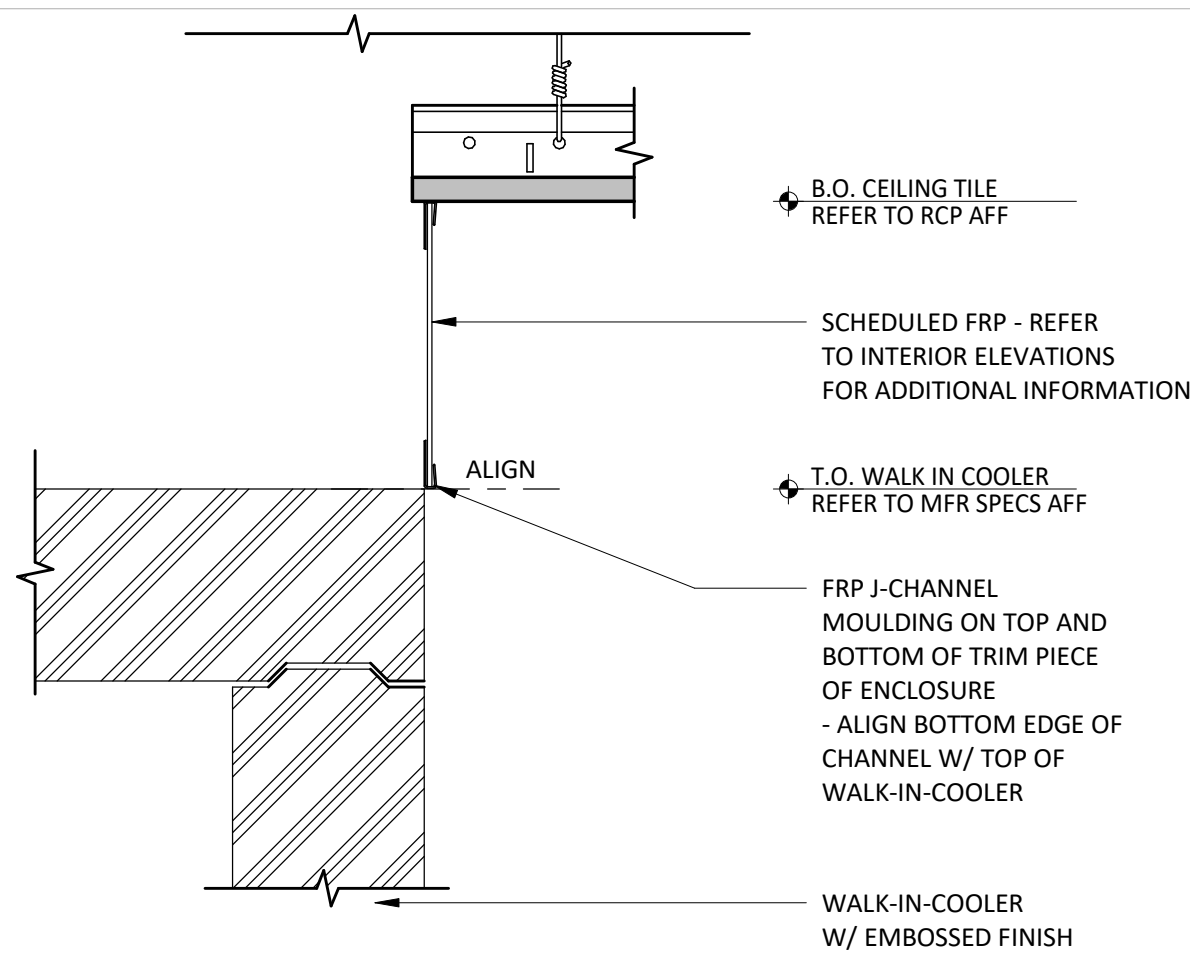

12 KITCHEN CEILING TRANSITION
SCALE: 3" = 1'-0"

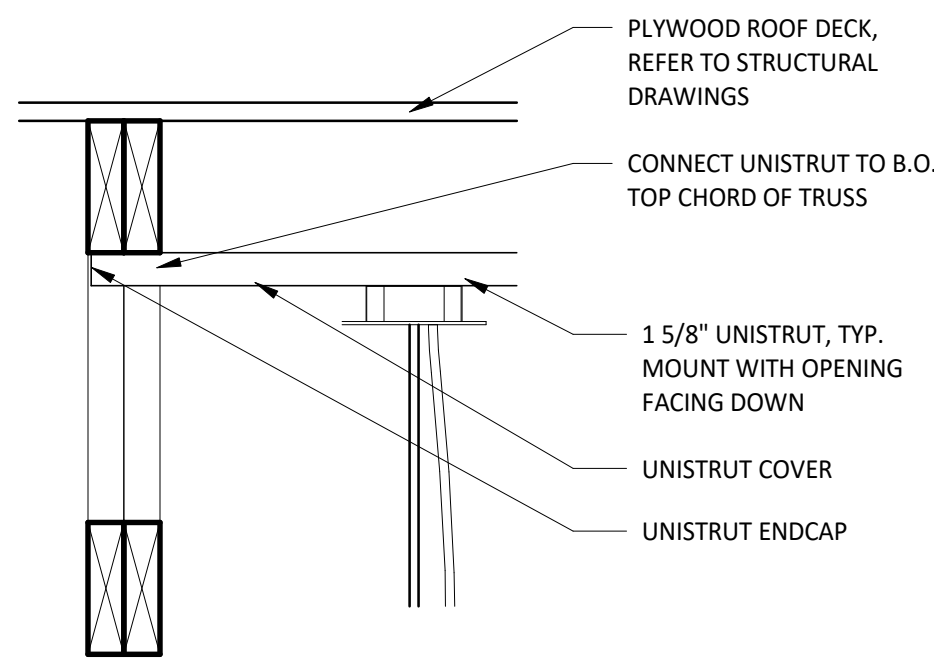

13 TYP. UNISTRUT MOUNTING DETAIL
SCALE: 1 1/2" = 1'-0"



CLIENT:




CHIPOTLE MEXICAN GRILL, INC.
PO BOX 18266
COLUMBUS, OH 43218-2666
TELEPHONE: (614) 318-2662
INTERNET: WWW.CHIPOTLE.COM

COPYRIGHT 2024
THIS DRAWING IS AN INSTRUMENT OF SERVICE AND
AS SUCH REMAINS THE PROPERTY OF CHIPOTLE
MEXICAN GRILL, INC. PERMISSION FOR USE OF THIS
DOCUMENT IS LIMITED AND CAN BE EXTENDED ONLY
BY WRITTEN AGREEMENT WITH CHIPOTLE MEXICAN
GRILL, INC.

PROJECT INFORMATION:

STORE NO.: 4757
"ANDERSON IN"
S SCATTERFIELD RD & 59TH STREET
ANDERSON, IN 46013

SEAL:

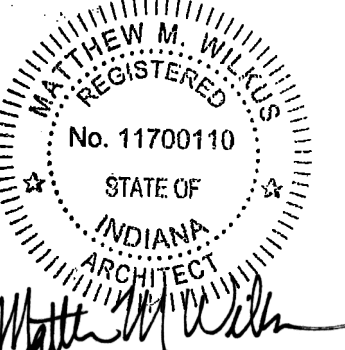

July 25, 2024

MATTHEW M. WILKUS
LICENSE #A11700110
(EXPIRES 12/31/2024)

PROJECT NO. 2022-0494

DRAWN BY RDB

CHECKED BY

ISSUE RECORD:

12/12/2023

06/19/2024

07/24/2024

PERMIT SET

BID SET

CONSTRUCTION SET


REVISIONS:

TITLE:


CEILING DETAILS

SHEET NUMBER:


A210

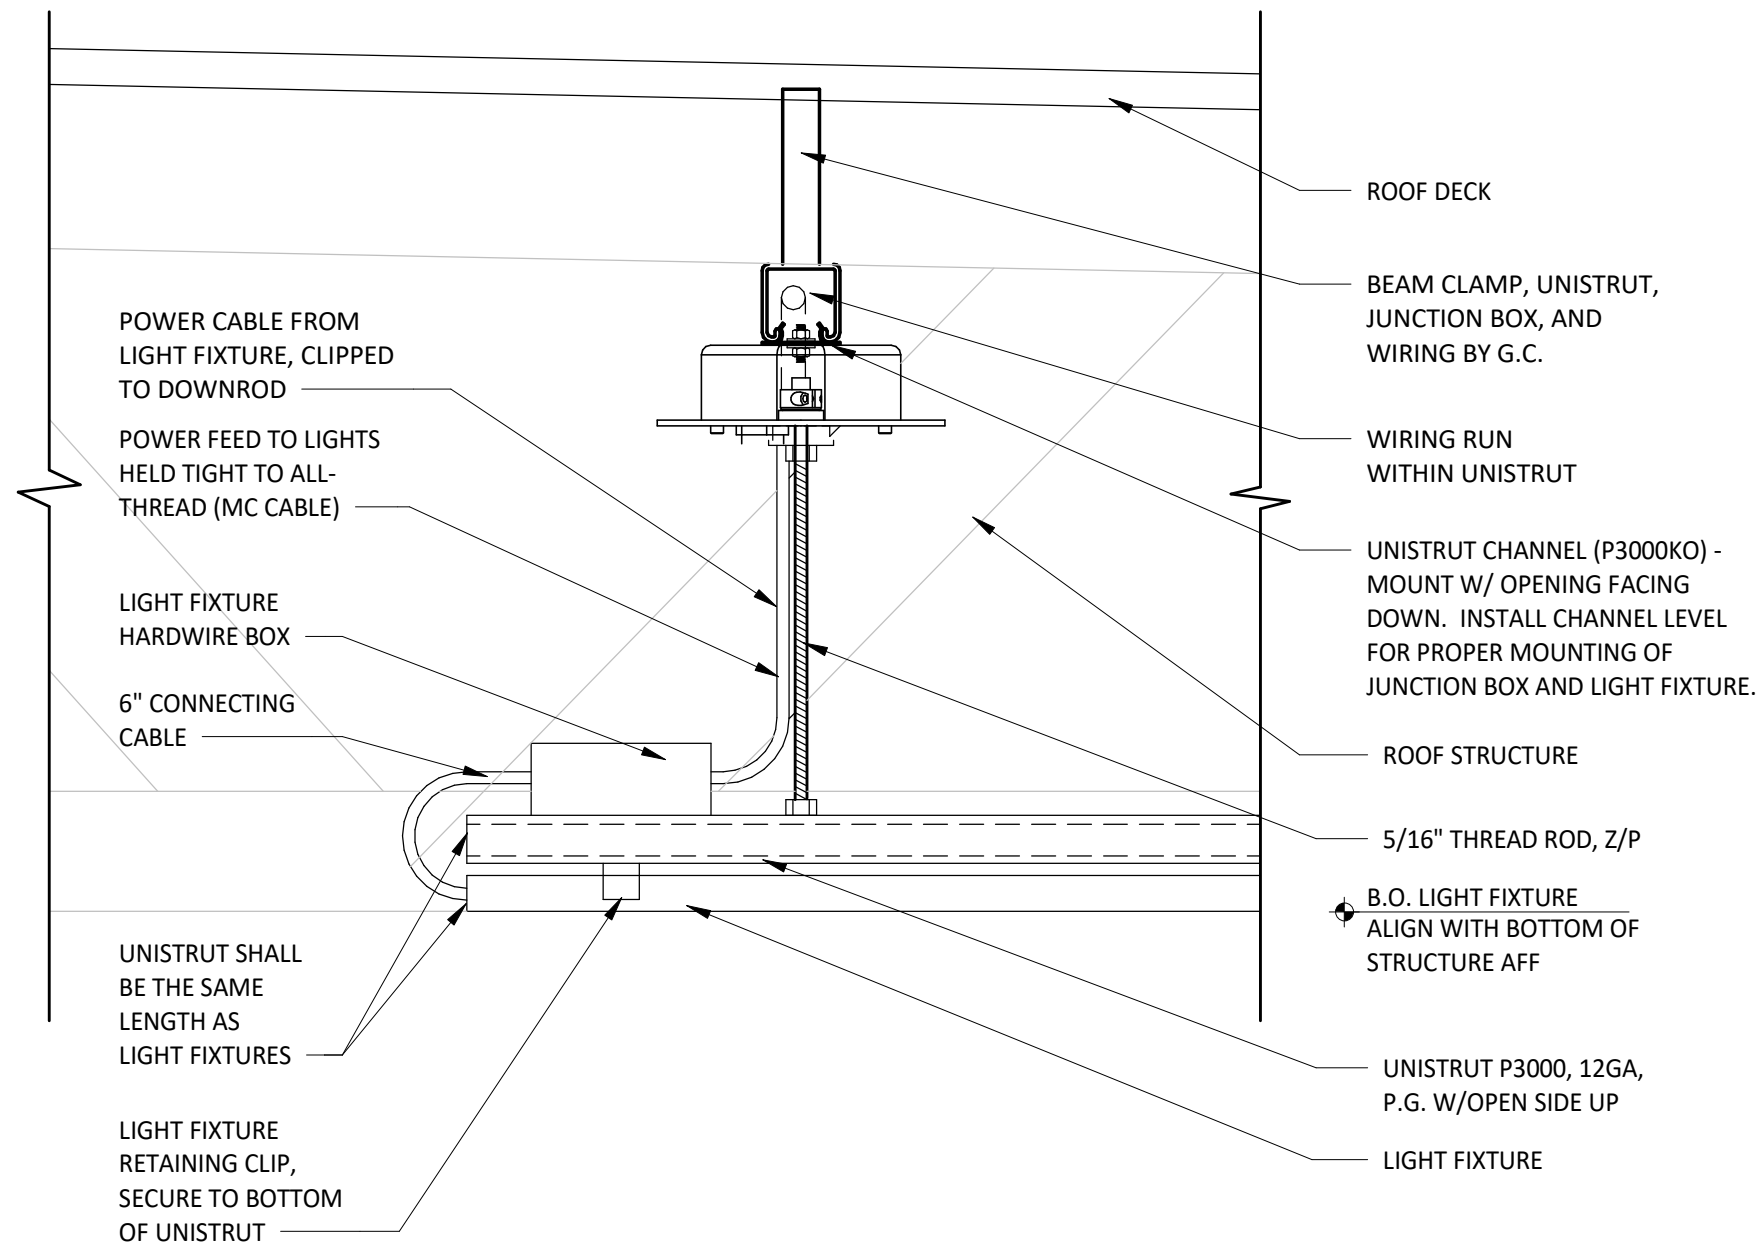


1 SUSPENDED STRIP LIGHT CONNECTION DETAIL
SCALE: 3" = 1'-0"

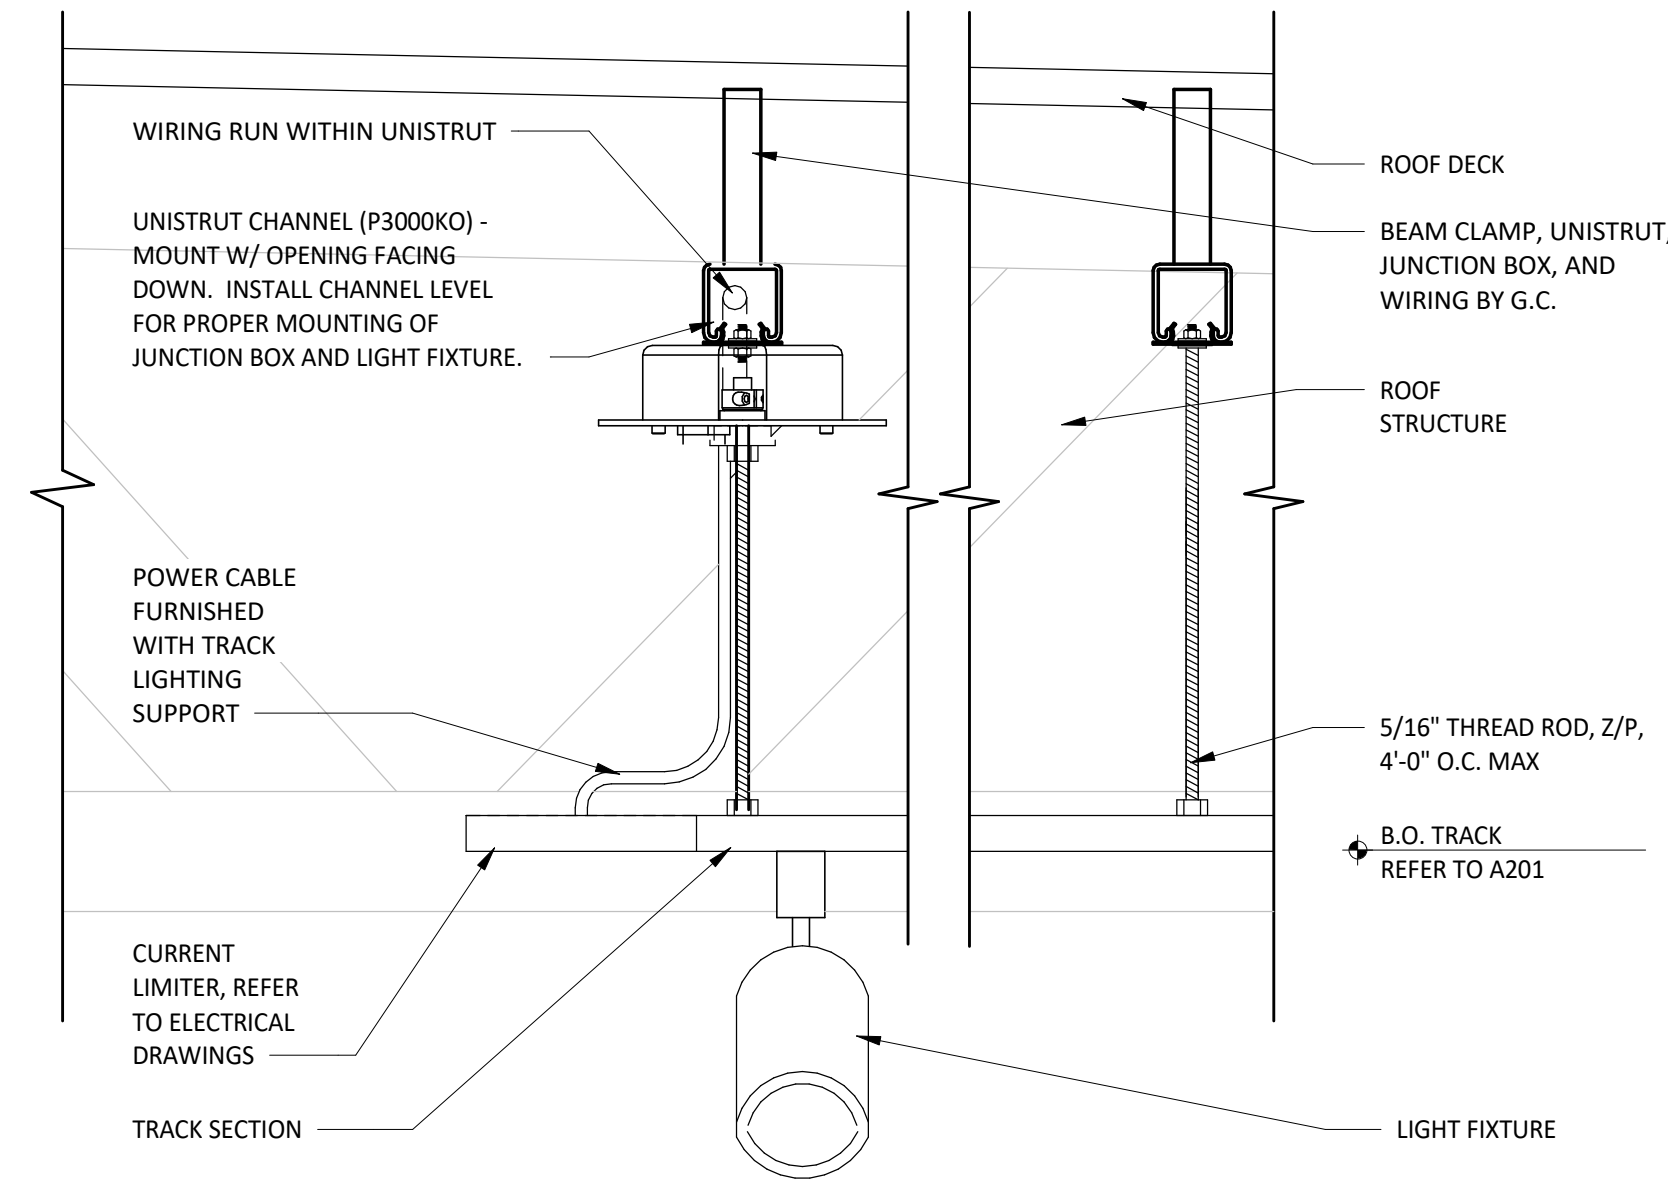

2 SUSPENDED TRACK LIGHT CONNECTION DETAIL
SCALE: 3" = 1'-0"

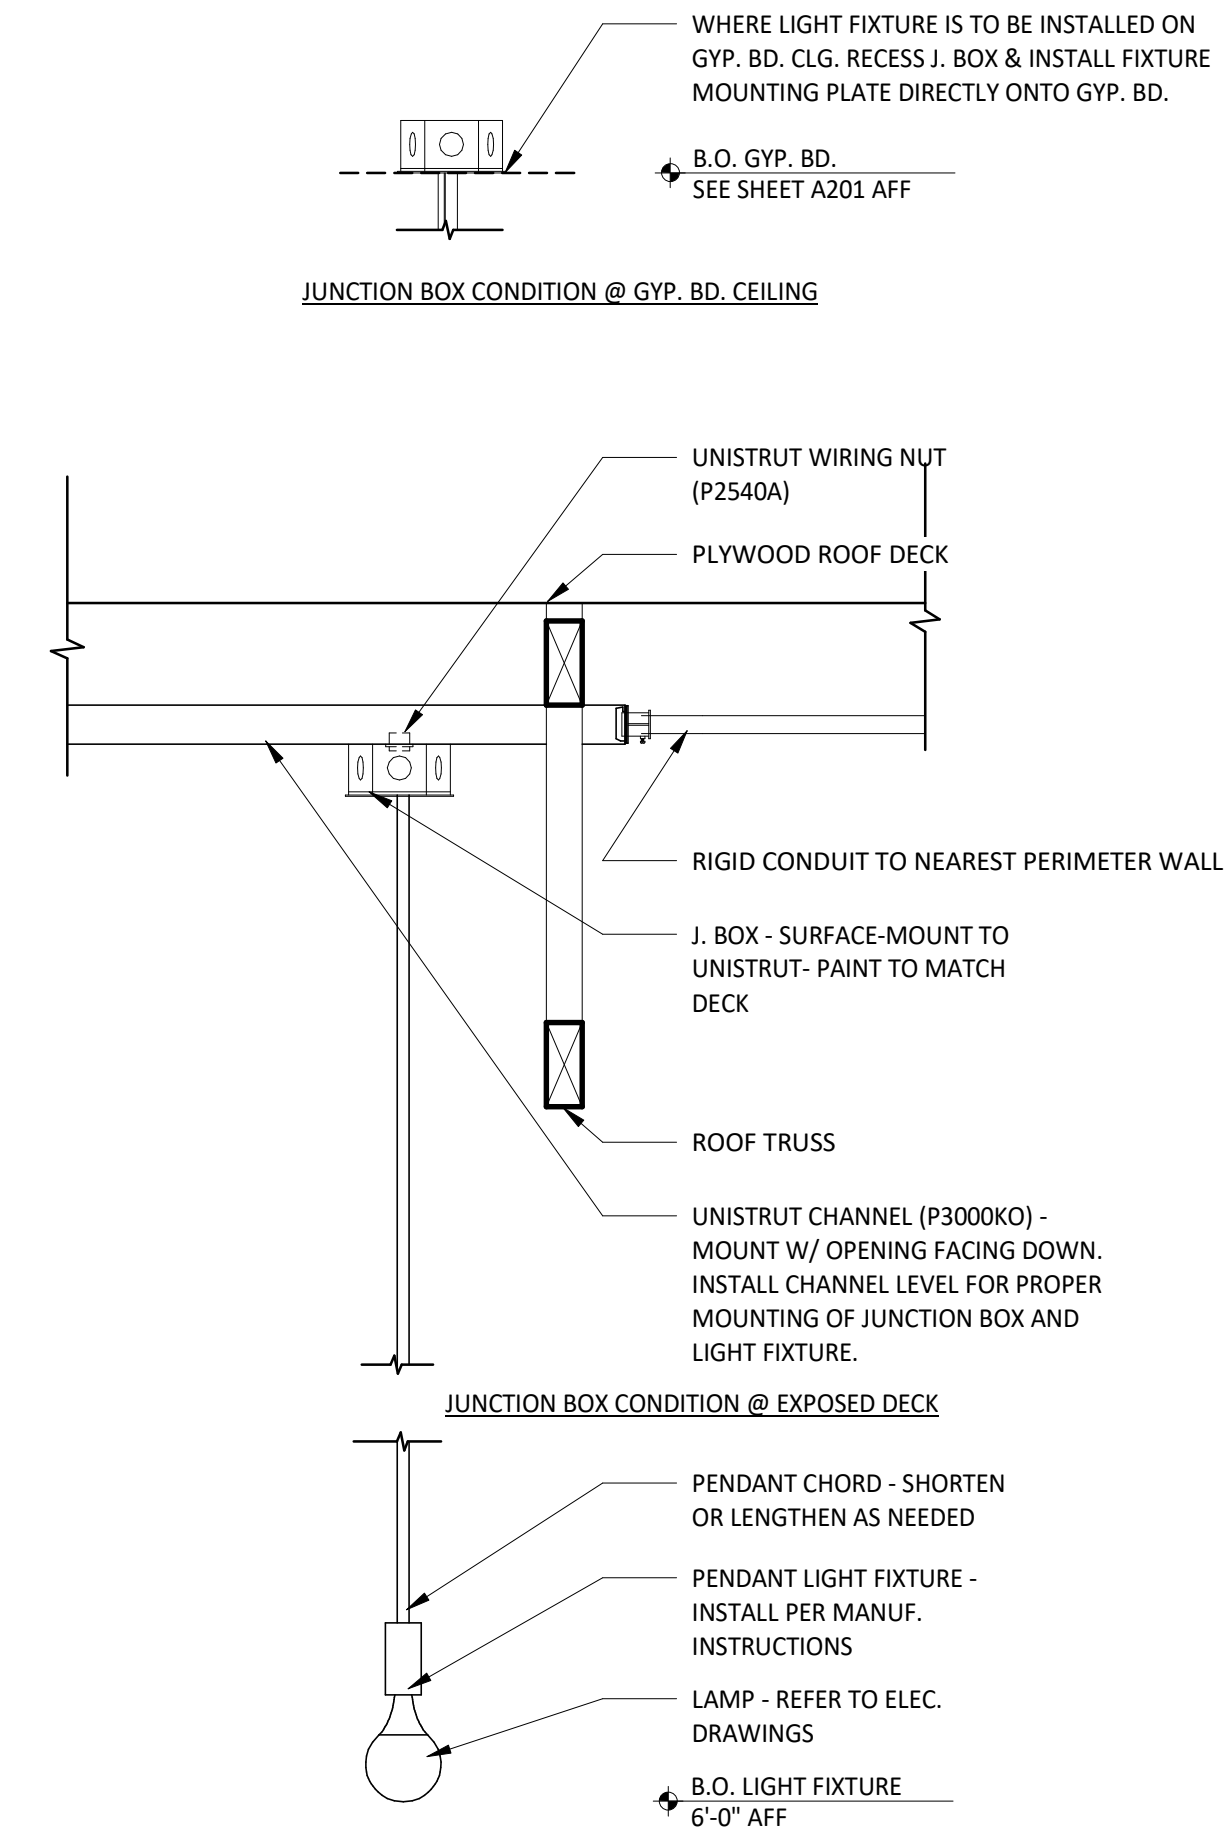

3 PENDANT LIGHT FIXTURE
SCALE: 1 1/2" = 1'-0"

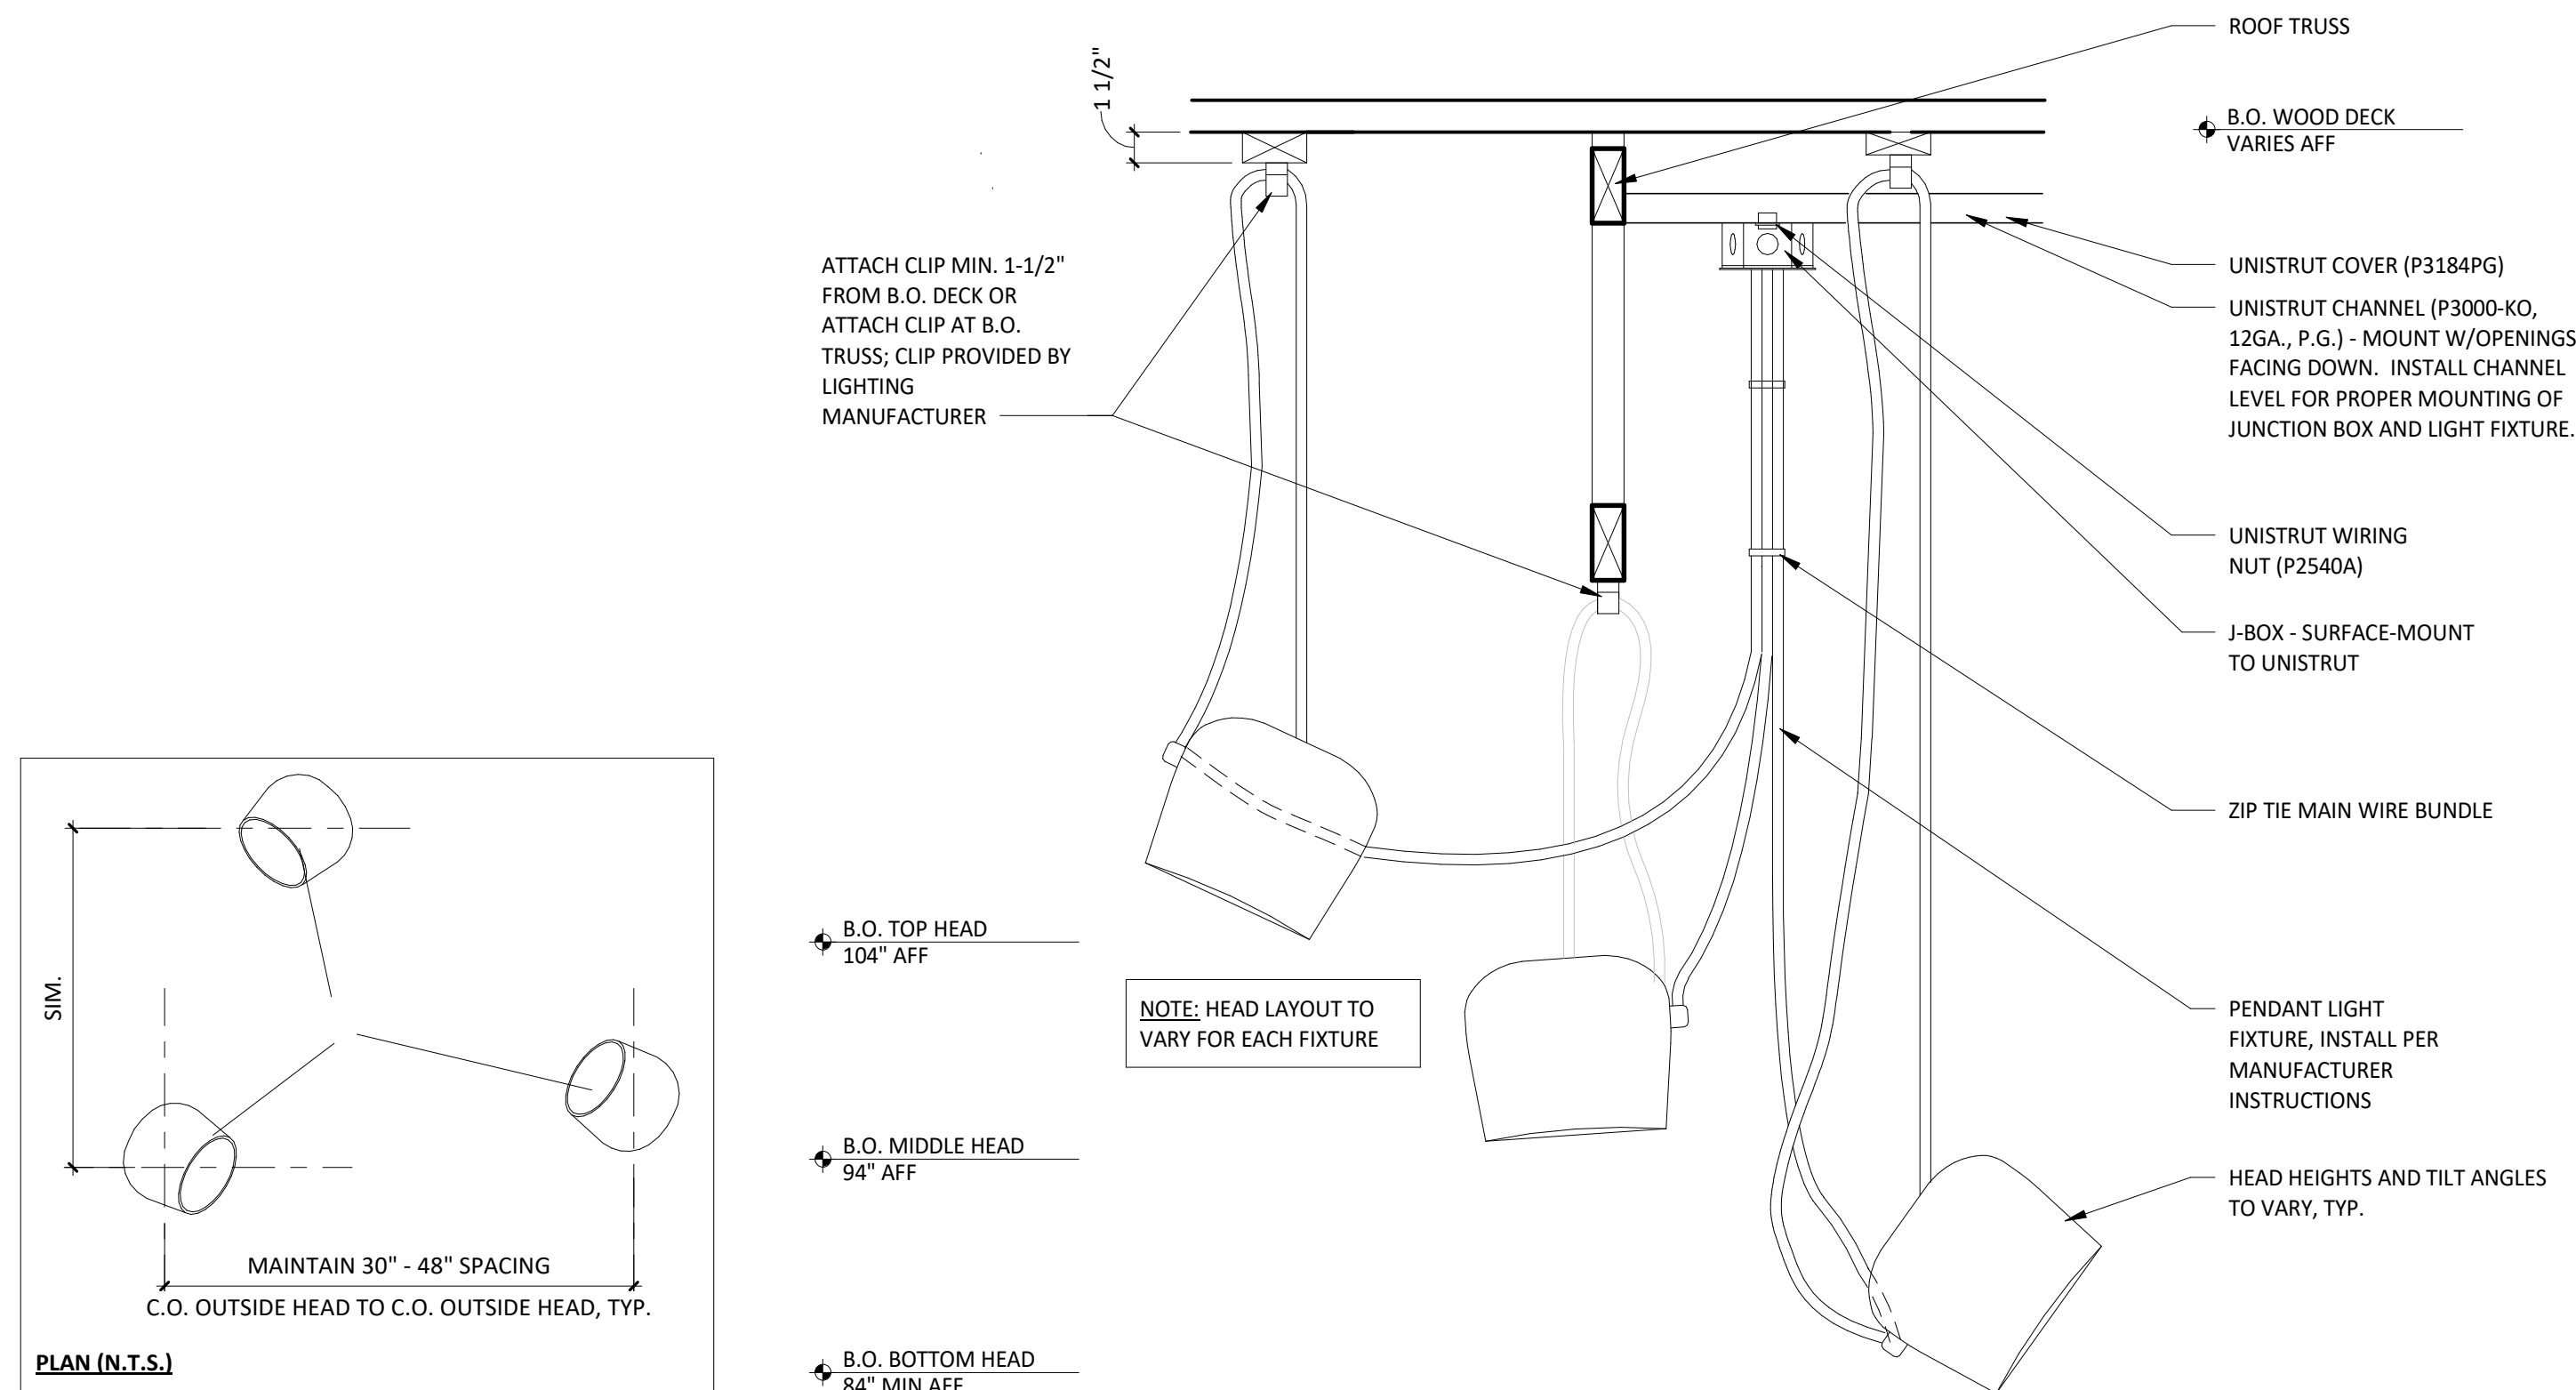

4 PENDANT LIGHT
SCALE: 1 1/2" = 1'-0"



CLIENT:




CHIPOTLE MEXICAN GRILL, INC.
PO BOX 18266
COLUMBUS, OH 43218-2666
TELEPHONE: (614) 318-2662
INTERNET: WWW.CHIPOTLE.COM

COPYRIGHT 2024
THIS DRAWING IS AN INSTRUMENT OF SERVICE AND AS SUCH REMAINS THE PROPERTY OF CHIPOTLE MEXICAN GRILL, INC. PERMISSION FOR USE OF THIS DOCUMENT IS LIMITED AND CAN BE EXTENDED ONLY BY WRITTEN AGREEMENT WITH CHIPOTLE MEXICAN GRILL, INC.

PROJECT INFORMATION:

STORE NO.: 4757
"ANDERSON IN"
S SCATTERFIELD RD & 59TH STREET
ANDERSON, IN 46013

SEAL:

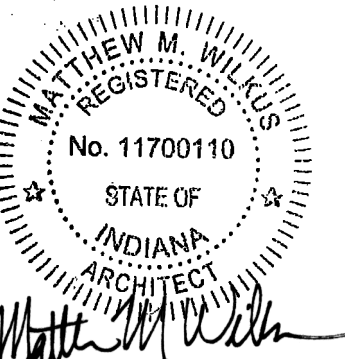

July 25, 2024

MATTHEW M. WILKUS
LICENSE #AR11700110
(EXPIRES 12/31/2024)

PROJECT NO. 2022-0494

DRAWN BY RDB

CHECKED BY

ISSUE RECORD:

12/12/2023	PERMIT SET
06/19/2024	BID SET
07/24/2024	CONSTRUCTION SET


REVISIONS:

TITLE:

LIGHTING DETAILS

SHEET NUMBER:

A211

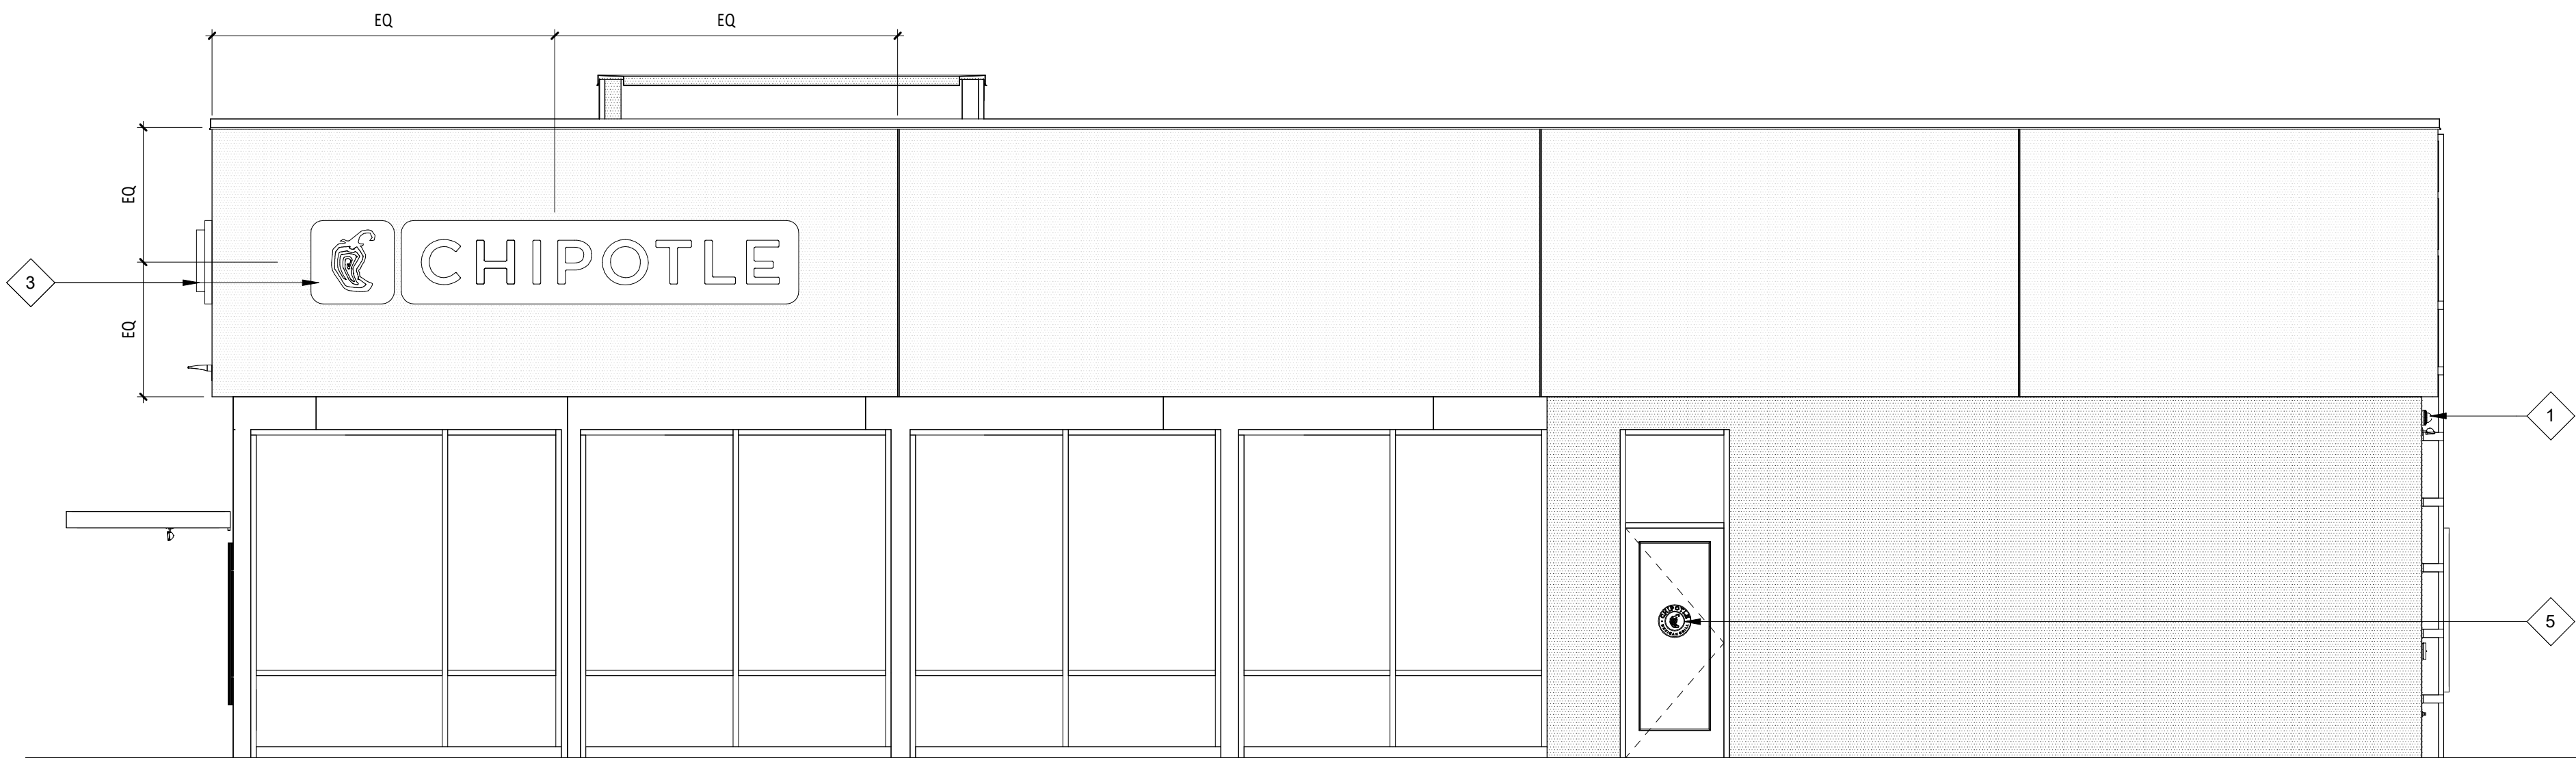


GENERAL NOTES - EXT. ELEV.

- A. SIGNAGE IS SHOWN ONLY FOR PLACEMENT AND SCALE. ALL SIGNAGE FOR REVIEW UNDER SEPARATE PERMIT, NOT PART OF THIS PERMIT SET.
B. EXTERIOR SIGNAGE PROVIDED BY TSV AND INSTALLED BY TSV. GC TO MAKE FINAL CONNECTION.


KEYNOTE LEGEND

- 1 LOCATION OF SECURITY CAMERAS TO BE INSTALLED BY GENERAL CONTRACTOR.
2 LOCATION OF REMOTE CO2 FILLER - INSTALL BETWEEN 36" AND 48" ABOVE FINISHED GRADE - VERIFY LOCATION WITH CHIPOTLE CONSTRUCTION MANAGER.
3 LOCATION OF TENANTS B-3 SIGNAGE - GENERAL CONTRACTOR TO COORDINATE BLOCKING REQUIREMENTS WITH SIGNAGE VENDOR.
4 6" VINYL ADDRESS LETTERS - COORDINATE ADOPTED REQUIREMENTS ON SIZE AND LOCATION WITH LOCAL JURISDICTION.
5 VINYL WINDOW GRAPHIC SUPPLIED BY TENANT, INSTALLED BY GC.
6 WOOD HANDLES SUPPLIED BY TENANT MEDALLION SUPPLIER, INSTALLED BY GC.


1 EXTERIOR ELEVATION
SCALE: 1/4" = 1'-0"

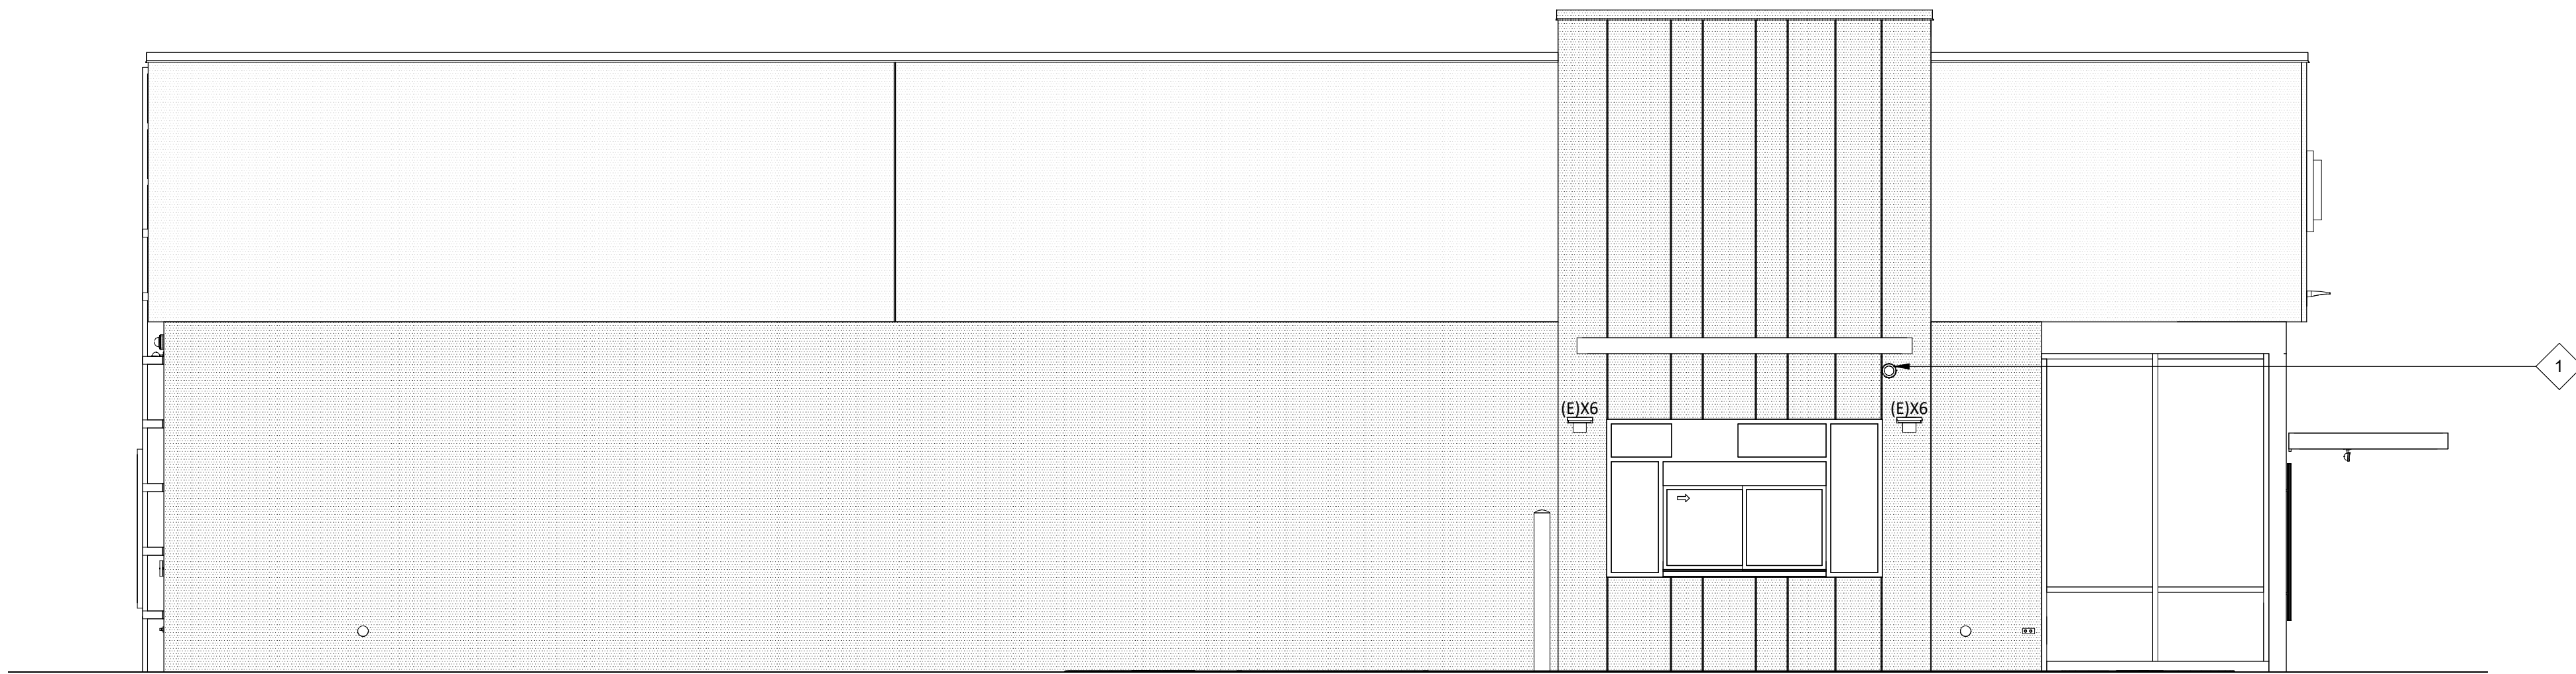

2 EXTERIOR ELEVATION
SCALE: 1/4" = 1'-0"

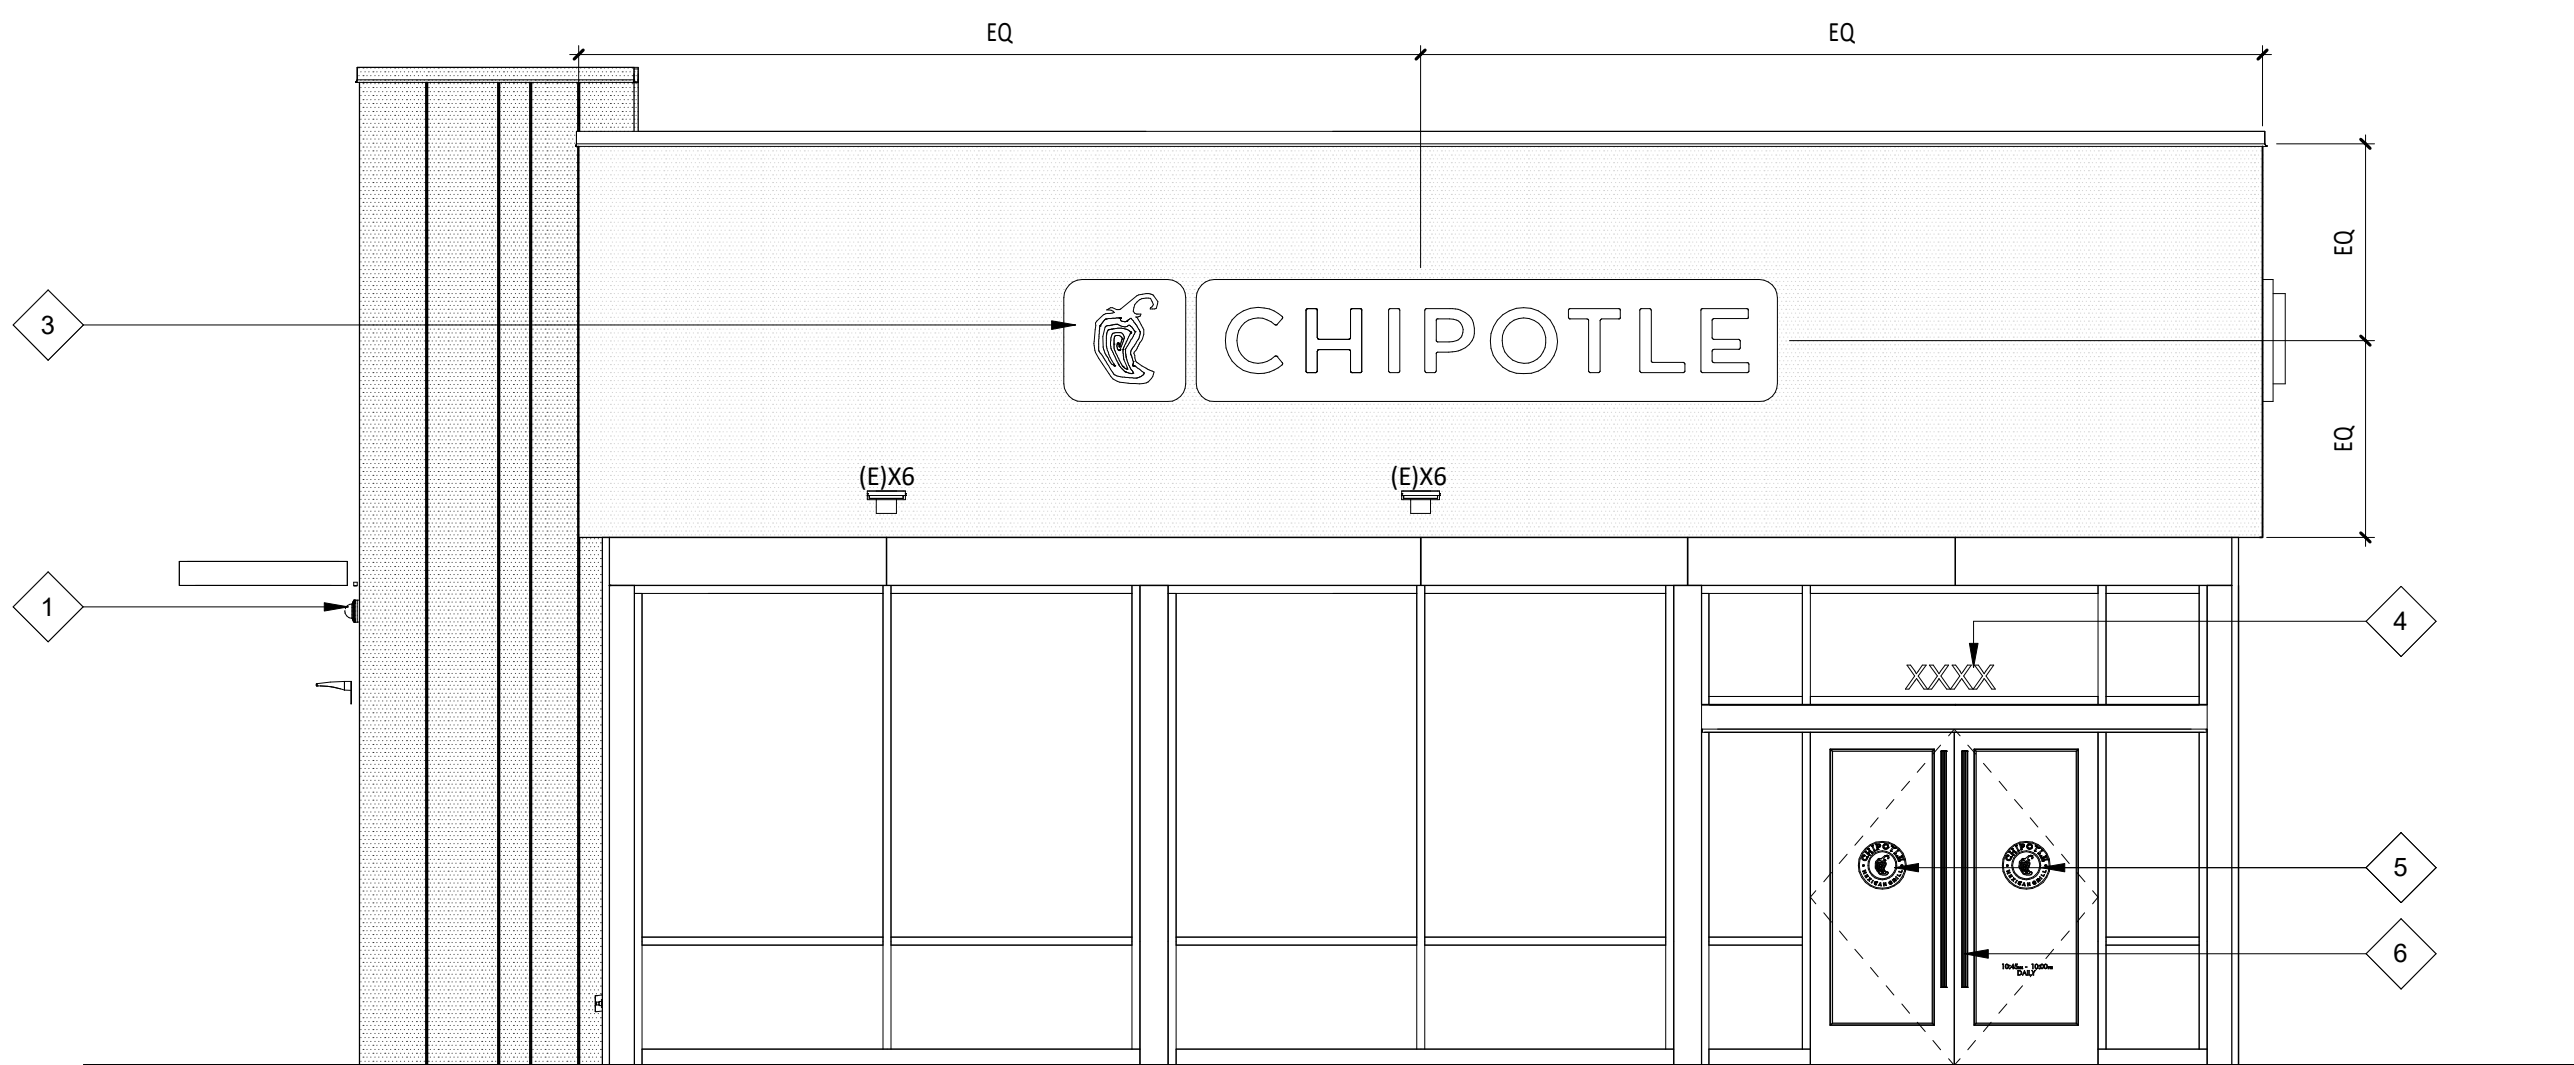

3 EXTERIOR ELEVATION
SCALE: 1/4" = 1'-0"

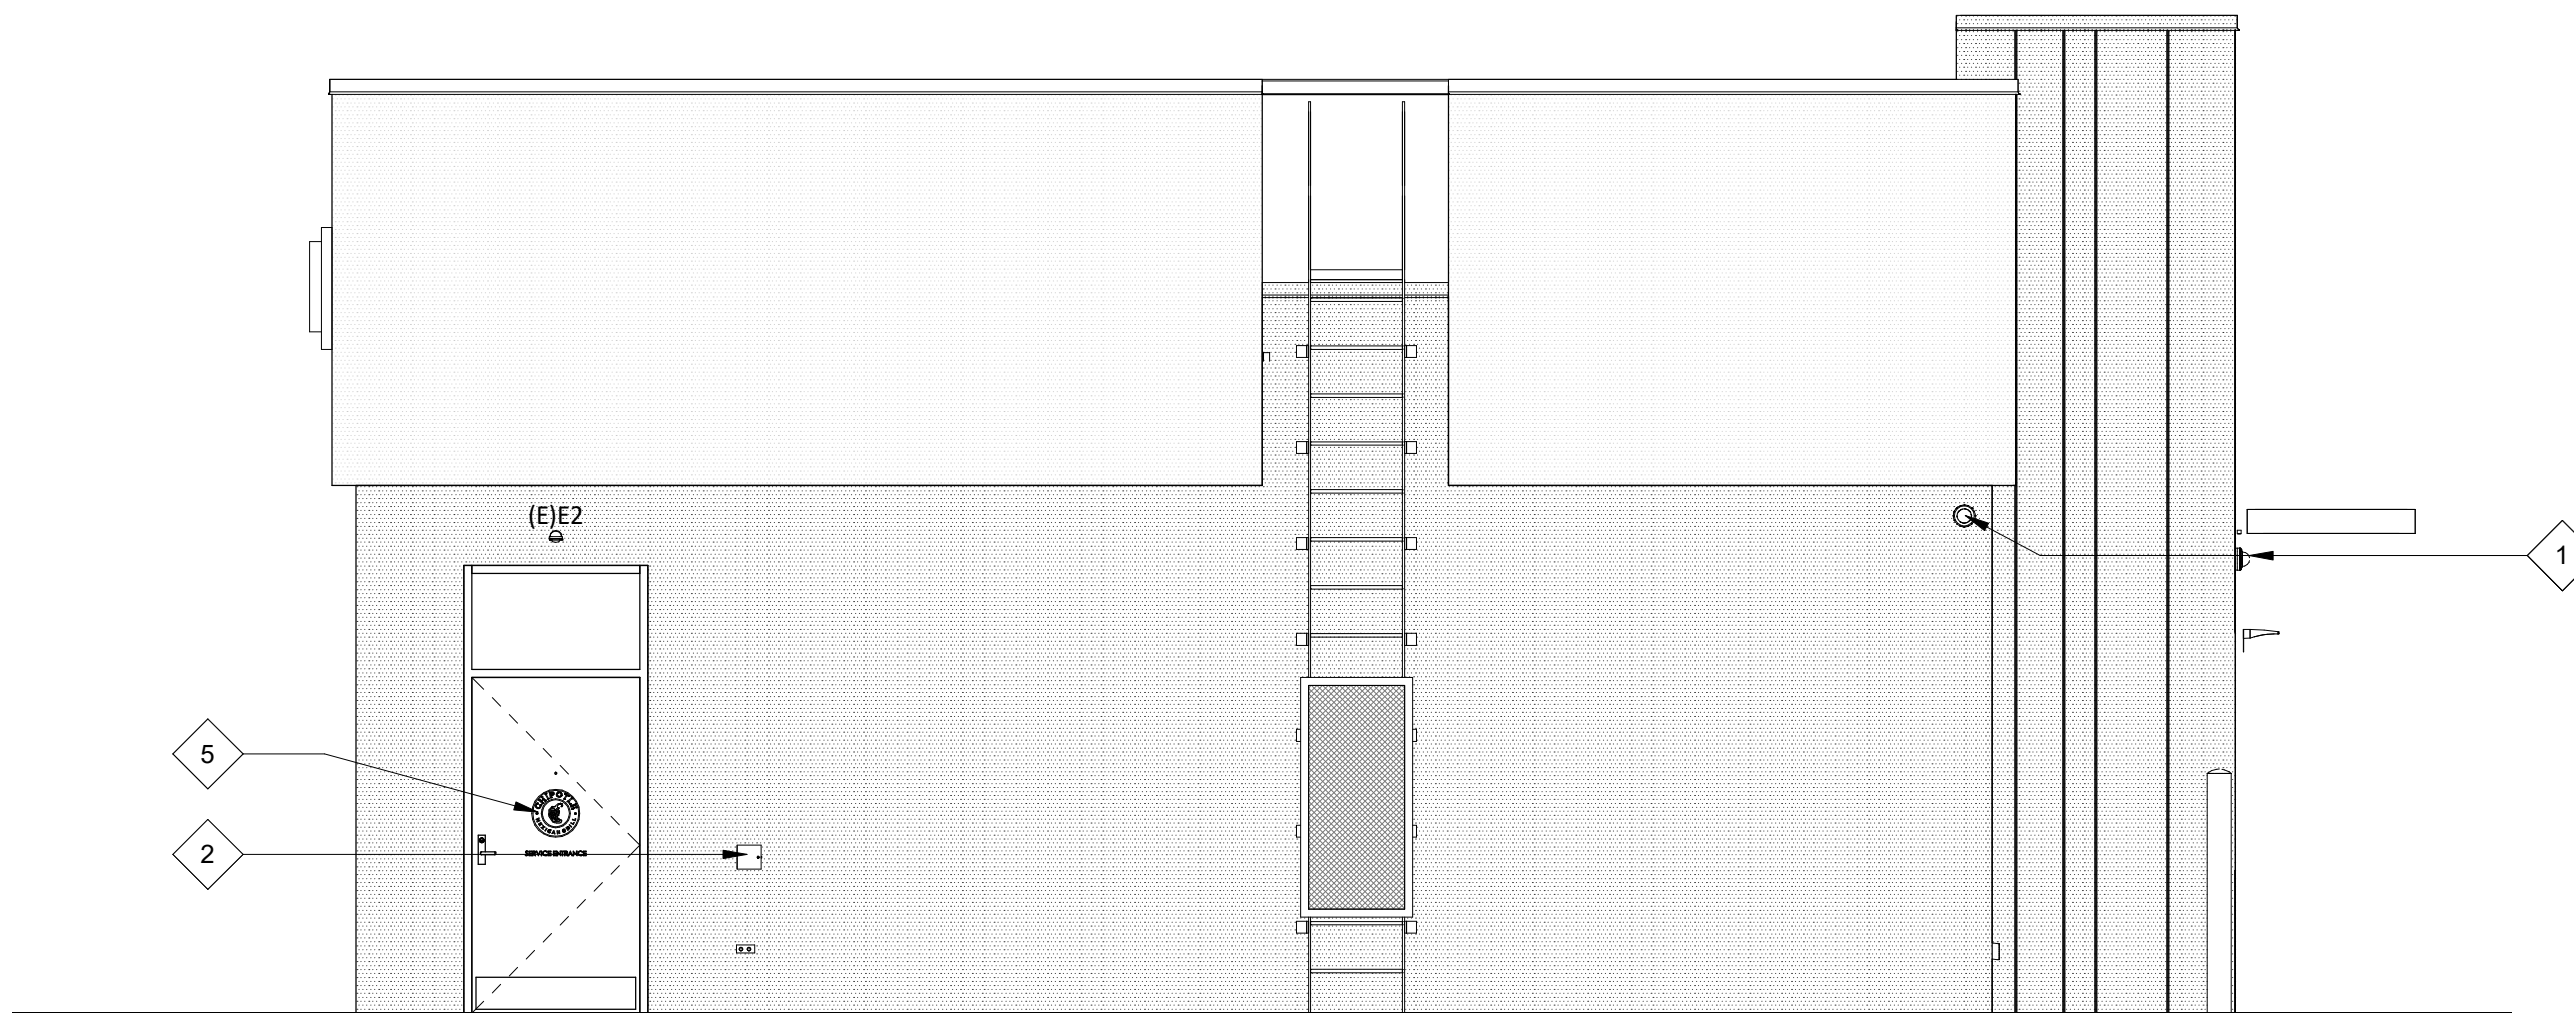

4 EXTERIOR ELEVATION
SCALE: 1/4" = 1'-0"



CLIENT:



CHIPOTLE MEXICAN GRILL, INC.
PO BOX 182966
COLUMBUS, OH 43218-2966
TELEPHONE: (614) 318-2692
INTERNET: WWW.CHIPOTLE.COM

COPYRIGHT 2024
THIS DRAWING IS AN INSTRUMENT OF SERVICE AND AS SUCH REMAINS THE PROPERTY OF CHIPOTLE MEXICAN GRILL, INC. PERMISSION FOR USE OF THIS DOCUMENT IS LIMITED AND CAN BE EXTENDED ONLY BY WRITTEN AGREEMENT WITH CHIPOTLE MEXICAN GRILL, INC.

PROJECT INFORMATION:

STORE NO.: 4757
"ANDERSON IN"
S SCATTERFIELD RD & 59TH STREET
ANDERSON, IN 46013

SEAL:



July 25, 2024

MATTHEW M. WILKUS
LICENSE #AR11700110
(EXPIRES 12/31/2024)

PROJECT NO. 2022-0494

DRAWN BY RDB

CHECKED BY

ISSUE RECORD:

12/12/2023 PERMIT SET
06/19/2024 BID SET
07/24/2024 CONSTRUCTION SET

REVISIONS:

TITLE:
EXTERIOR
ELEVATIONS

SHEET NUMBER:

A301



SCALE: 1" = 1'-0"

2 MOPUS SEC
SCALE: 1" = 1'-0"


DOOR SCHEDULE

TAG	ROOM	DOOR STATUS *	FRAME STATUS	DOOR DESCRIPTION	DOOR WIDTH	DOOR HEIGHT	THICKNESS	DOOR TYPE	DOOR FINISH	FRAME TYPE	MATERIAL	STILE	HARDWARE SET	HARDWARE STATUS*	FIRE RATING	REMARKS
1	MAIN ENTRY	EXISTING	EXISTING	DOUBLE STOREFRONT (WIDE STILE, WOOD PULL/PUSH)	6' - 0"	7' - 0"	0' - 1 3/4"	A	SEE A301	STOREFRONT	ALUM	WIDE (5")	1A	EXISTING/NEW	-	1,2,4,5
2	PASSAGE	EXISTING	EXISTING	SINGLE STOREFRONT (WIDE STILE, NON-OFFSET, PANIC)	3' - 0"	7' - 0"	0' - 1 3/4"	A	SEE A301	STOREFRONT	ALUM	WIDE (5")	2A	EXISTING	-	1,3,4,5
3	KITCHEN	EXISTING	EXISTING	HM REAR KITCHEN (STANDARD)	3' - 6"	7' - 0"	0' - 1 3/4"	D	D1/D2 (SEE A120)	2	H.M.	-	3	EXISTING	-	1,4,7
4	MEN'S RESTROOM	NEW	NEW	RESTROOM (SINGLE-OCCUPANT, STANDARD)	3' - 0"	7' - 0"	0' - 1 3/4"	B	D1 (SEE A120)	1	H.M.	-	6	NEW	-	
5	WOMEN'S RESTROOM	NEW	NEW	RESTROOM (SINGLE-OCCUPANT, STANDARD)	3' - 0"	7' - 0"	0' - 1 3/4"	B	D1 (SEE A120)	1	H.M.	-	5	NEW	-	
6	OFFICE	NEW	NEW	MANAGER'S OFFICE	3' - 0"	7' - 0"	0' - 1 3/4"	C	D1 (SEE A120)	1	H.M.	-	4	NEW	-	
7	MAIN ENTRY	NEW	NEW	SINGLE STOREFRONT - VESTIBULE (WIDE STILE, NON-OFFSET)	3' - 0"	7' - 0"	0' - 1 3/4"	A	SEE A301	STOREFRONT	ALUM	WIDE (5")	2D	NEW	-	5
8	MAIN ENTRY	NEW	NEW	SINGLE STOREFRONT - VESTIBULE (WIDE STILE, NON-OFFSET)	3' - 0"	7' - 0"	0' - 1 3/4"	A	SEE A301	STOREFRONT	ALUM	WIDE (5")	2D	NEW	-	5

DOOR REMARKS

- DOORS WITH REMARK #1 TO BE KEYED THE SAME
- EXIT INDICATOR ARRIVES WITH SIGNS STATING "THIS DOOR TO REMAIN UNLOCKED DURING BUSINESS HOURS" AND "THIS DOOR TO REMAIN UNLOCKED WHEN THE BUILDING IS OCCUPIED". VERIFY REQUIRED SIGN WORDING WITH LOCAL JURISDICTION PRIOR TO INSTALLATION. ONE SIGN IS TO BE PLACED IN A VISIBLE LOCATION ABOVE THE DOORS.
- THERE IS TO BE NO EXTERIOR HOLE OR CYLINDER
- USE NON-SHRINK STRUCTURAL GROUT BED UNDER THRESHOLD
- BLACK DOOR SWEEP TO BE USED WITH CHARCOAL STOREFRONT. LIGHT GRAY DOOR SWEEP TO BE USED WITH CLEAR ANODIZED ALUMINUM STOREFRONT
- IF STATUS IS "EXISTING" G.C. TO DETERMINE CONDITION OF EXISTING HARDWARE. IF HARDWARE IS IN POOR CONDITION, PROVIDE HARDWARE IN HARDWARE SCHEDULE. CONFIRM REPLACEMENT WITH CHIPOTLE CM.
- REAR KITCHEN DOOR TO BE PAINTED 'BLACK' ON INTERIOR AND 'KNIGHTS ARMOR' ON EXTERIOR U.N.O.

TYPICAL EXTERIOR DOOR TYPES

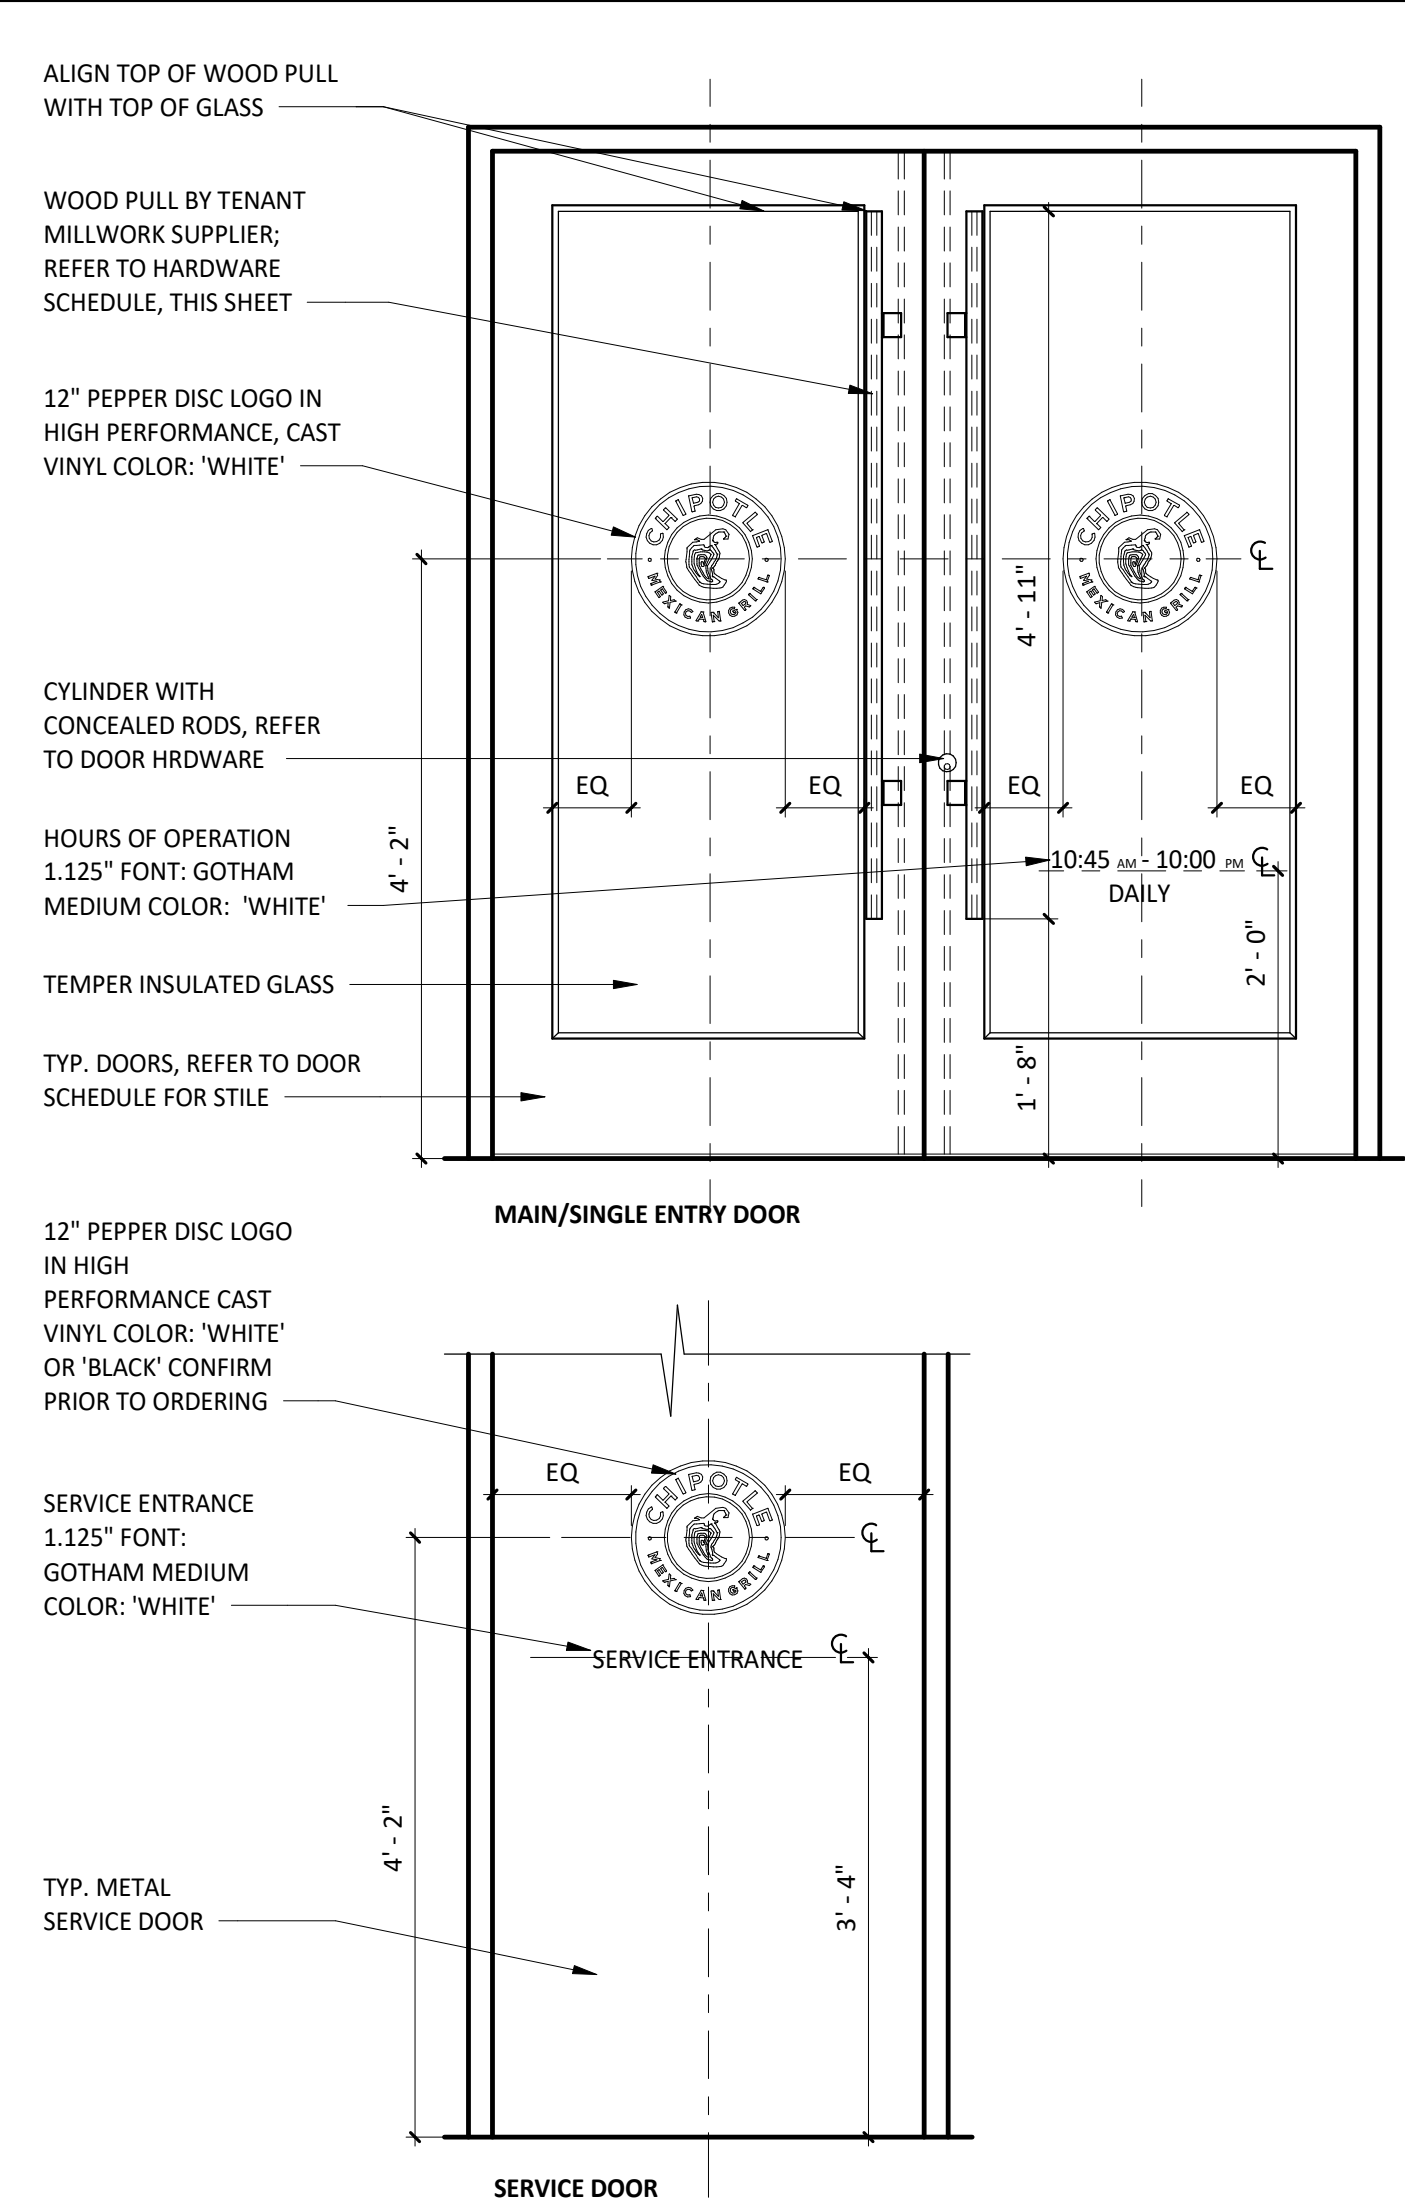

EXISTING HARDWARE SETS

G.C. TO CONFIRM ALL REQUIRED EXISTING HARDWARE IS PRESENT AND IS IN WORKING CONDITION. IF HARDWARE IS IN POOR CONDITION OR MISSING, PROVIDE HARDWARE IN HARDWARE SCHEDULE BELOW; CONFIRM REPLACEMENT WITH CHIPOTLE CM.

SET 1 - MAIN ENTRY - PAIR - WOOD PULL/PUSH

(2)	HINGE	HAGER, MODEL 780-224HD-83"-CLR
(2)	MORTISE CYLINDER	SCHLAGE, MODEL 80-103, BRUSHED CHROME; C.O. CYLINDER AT 34" MIN. FROM BOTTOM OF DOOR
(2)	TEMP CORE	SCHLAGE, MODEL 80-035 INTERCHANGEABLE CORE, (BRUSHED CHROME)
(1)	DEADBOLT	ADAMS RITE, MODEL MS18505-310-628
(1)	EXIT INDICATOR	ADAMS RITE, MODEL 4089-00-130
(1)	HEADER BOLT	ADAMS RITE, MODEL 4016-30-01
(1)	THRESHOLD BOLT	ADAMS RITE, MODEL 4015-18-18
(2)	CLOSER	DORMA, MODEL 8916-AF89P (TOP JAMB), (ALUMINUM)
(2)	DOOR STOP	IVES, MODEL FS18S (ALUMINUM)
(2)	OVERHEAD STOP	GLYNN-JOHNSON, MODEL 4545-SP28 (ALUMINUM)
(2)	CLOSER BACK PLATE	DORMA, MODEL BP89, ALUMINUM
(1)	THRESHOLD	PEMKO, MODEL 2750A-72 (SIZE 72")
(1)	SMOKE SEAL	REESE, MODEL 797B-21
(2)	DOOR SWEEP	PEMKO, MODEL SF5C-200-36 (36" DOOR), OWNER FURNISHED

SET 2A - ENTRY - SINGLE - NON-OFFSET - PANIC HARDWARE


(1)	HINGE	HAGER, MODEL 780-224HD-83"-CLR
(1)	PUSH HARDWARE	ADAMS RITE, MODEL 8801-36-628 (ALUMINUM FINISH, 36" DOOR); C.O. EXIT DEVICE AT 38" FROM BOTTOM OF DOOR
(1)	PULL HARDWARE	HAGER, MODEL 4G US32D (8" CTC), CENTER ON DOOR STILE
(1)	CLOSER	DORMA, MODEL 8916-AF89P-689 (TOP JAMB), (ALUMINUM)
(1)	CLOSER BACK PLATE	DORMA, MODEL BP89, ALUMINUM
(1)	OVERHEAD STOP	GLYNN-JOHNSON, MODEL 4545-US32D (ALUMINUM)
(1)	THRESHOLD	REESE, MODEL S424A-36 (SIZE 36")
(1)	SMOKE SEAL	REESE, MODEL 797B-21
(1)	DOOR SWEEP	PEMKO, MODEL SF5C-200-36 (36" DOOR), OWNER FURNISHED
(1)	DOOR STOP	IVES, MODEL FS18S (ALUMINUM)

SET 3 - REAR EXIT - SINGLE

(1)	HINGE	HAGER, MODEL 780-224HD-83"-CLR
(1)	PUSH HARDWARE	FALCON, MODEL 25-R-EO-4"-US28 (SIZE 42")
(1)	PULL HARDWARE	FALCON, MODEL 510L-DANE-LHR-US26D, ALUMINUM (EXTERIOR SIDE)
(1)	RIM CYLINDER	GLS, MODEL RCIC-7-LZ-626
(1)	TEMP CORE	SCHLAGE, MODEL 80-035 INTERCHANGEABLE CORE (FINISH: BRUSHED CHROME)
(1)	CLOSER	DORMA, MODEL 8916-AF89P-689 (TOP JAMB), ALUMINUM
(1)	CLOSER BACK PLATE	DORMA, MODEL BP89, ALUMINUM
(1)	THRESHOLD	REESE, MODEL S239A-42, (SIZE 42")
(1)	WEATHERSTRIP	REESE, MODEL D575C-4070
(1)	DOOR SWEEP	PEMKO, MODEL SF5C-200-42 (42" DOOR) (BLACK) OWNER FURNISHED
(1)	DOOR VIEWER	IVES, MODEL U698B26D, C.O. VIEWER AT 60" FROM BOTTOM OF DOOR
(1)	DOOR SILENCERS	IVES, MODEL SR64
(1)	DOOR BUZZER	TRINE, MODEL 668
(1)	KICKPLATE	HIAWATHA, MODEL KP834-US32D

VESTIBULE FRAME TYPES

*GENERAL NOTES: ALL STOREFRONT TO BE ANODIZED ALUMINUM (COLOR AS NOTED) W/ THERMAL BREAKS; ALL GLAZING TO BE 1/4" CLEAR SAFETY GLAZING U.N.O. PROVIDE HEAD RECEPTORS WHERE NOTED

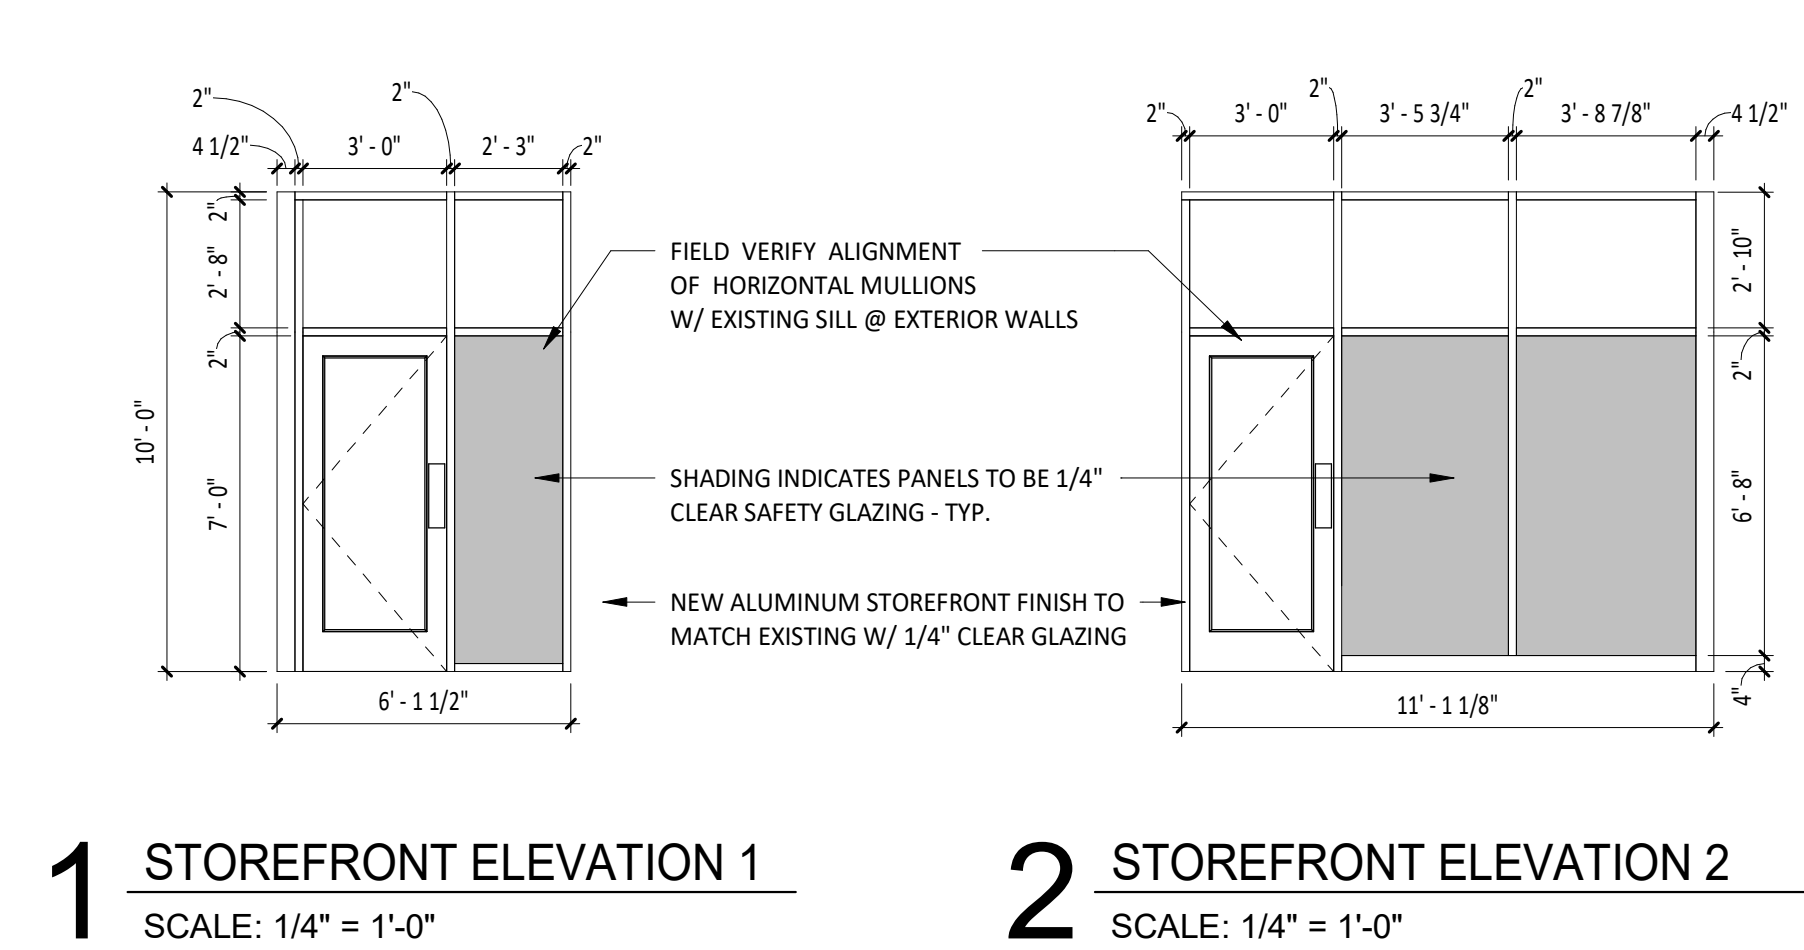

GENERAL DOOR HARDWARE

- ALL EGRESS DOORS SHALL BE READILY OPENABLE FROM THE EGRESS SIDE WITHOUT THE USE OF A KEY OR SPECIAL KNOWLEDGE OR EFFORT.
- LATCHES, HANDLES, PANIC BARS AND ALL DOOR HARDWARE WILL COMPLY WITH SECTION 7.2 OF NFPA 101 PER THE SPECIFICATIONS.
- THE MANAGER HAS A KEY TO UNLOCK RESTROOM DOORS, FROM THE OUTSIDE IN CASE OF AN EMERGENCY.
- ALL DOORS TO REMAIN UNLOCKED DURING BUSINESS HOURS.
- SEE THIS SHEET FOR EXTERIOR DOOR SIGNAGE INFO.
- MAXIMUM EFFORT TO OPERATE EXTERIOR OR INTERIOR DOORS WITH CLOSERS SHALL NOT EXCEED 5 POUNDS. THIS MAY BE INCREASED TO 15 POUNDS FOR FIRE-RATED DOORS.
- ALL NEW HOLLOW METAL DOORS, FRAMES AND HARDWARE TO BE FURNISHED BY TENANT HARDWARE SUPPLIER AND INSTALLED BY TENANT G.C. CALL PETE KLIMEK WITH TWIN CITY HARDWARE AT 763-535-4660 TO ARRANGE DELIVERY. NEW VESTIBULE STOREFRONT DOORS AND DOOR HARDWARE ARE TO BE PROVIDED BY TENANT G.C.
- THE BOTTOM 10 INCHES OF ALL DOORS SHALL HAVE A SMOOTH, UNINTERRUPTED SURFACE TO ALLOW THE DOOR TO BE OPENED BY A WHEELCHAIR FOOTREST WITHOUT CREATING A TRAP OR HAZARDOUS CONDITION.
- ALL SUPPORT SIGNAGE INSTALLED BY G.C.
- ALL SUPPORT SIGNAGE PROVIDED BY TENANT'S SUPPORT SIGNAGE SUPPLIER.
- ALL HARDWARE SHALL MATCH STOREFRONT, VERIFY WITH ARCHITECT AND/OR CHIPOTLE CONSTRUCTION MANAGER PRIOR TO ORDERING.

NEW HARDWARE SETS

SET 1 - MAIN ENTRY - PAIR - WOOD PULL/PUSH

(2)	PUSH HARDWARE	1 1/2" DIAMETER WOOD PULL, VARIES HIGH - PROVIDED BY MILLWORK SUPPLIER. MOUNT TOP OF PULLS FLUSH WITH TOP OF GLAZING STOP IN DOOR, RE: SHOP DRAWINGS
(2)	PULL HARDWARE	1 1/2" DIAMETER WOOD PULL, VARIES HIGH - PROVIDED BY MILLWORK SUPPLIER. MOUNT TOP OF PULLS FLUSH WITH TOP OF GLAZING STOP IN DOOR, RE: SHOP DRAWINGS

SET 2D - ENTRY - SINGLE - VESTIBULE

(1)	HINGE	HAGER, MODEL 780-224HD-83"-CLR
(1)	PUSH HARDWARE	HAGER, MODEL 30S, 4"X16" US32D STAINLESS STEEL
(1)	PULL HARDWARE	HAGER, MODEL 4G US32D (8" CTC), CENTER ON DOOR STILE
(1)	CLOSER	DORMA, MODEL 8916-AF89P-689 (TOP JAMB), (ALUMINUM)
(1)	DOOR STOP	IVES, MODEL FS18S (ALUMINUM)
(1)	CLOSER BACK PLATE	DORMA, MODEL BP89, ALUMINUM
(1)	KICKPLATE	HIAWATHA, MODEL KP834-US32D (SIZE 8" X 34")

SET 4 - MANAGER'S OFFICE

(3)	HINGE	STANLEY, MODEL FB8179-4.5-US26 (06-8438)
(1)	LOCKSET	SCHLAGE, MODEL L9453L-06A-626
(1)	TEMP CORE	SCHLAGE, MODEL 80-035 INTERCHANGEABLE CORE (FINISH: BRUSHED CHROME)
(1)	KICKPLATE	HIAWATHA, MODEL KP834-32D
(1)	DOOR STOP	DON-JO, MODEL 1407-630, STAINLESS STEEL
(3)	DOOR SILENCERS	IVES, MODEL SR64
(1)	SECURITY WINDOW	AIR LOUVERS, MODEL VSL1212TEMPPAK SLIMLINE 12" X 12" X 1/4" LITE KIT (10" X 10" GLASS VISIBLE)


SET 5 - RESTROOM - SINGLE OCCUPANT - STANDARD

(3)	HINGE	STANLEY, MODEL FB8179-4.5-US26 (06-8438)
(1)	CLOSER	FALCON, MODEL: SC61xRW/PAXALU
(1)	LOCKSET	SCHLAGE, MODEL AL40S-NEP-626
(1)	DOOR STOP	DON-JO, 1407-630
(3)	DOOR SILENCERS	IVES, MODEL SR64
(2)	KICKPLATE	HIAWATHA, MODEL KP834-32D
(1)	COAT HOOK	MILLS, MODEL FT6519, SUPPLIED BY WASHROOM ACCESSORIES VENDOR, MOUNT T.O. HOOK AT 47 1/2" AFF


SET 6 - RESTROOM - SINGLE OCCUPANT - STANDARD

(3)	HINGE	STANLEY, MODEL FB8179-4.5-US26 (06-8438)
(1)	CLOSER	FALCON, MODEL: SC61xRW/PAXALU
(1)	LOCKSET	SCHLAGE, MODEL AL40S-NEP-626
(1)	DOOR STOP	DON-JO, 1407-630
(3)	DOOR SILENCERS	IVES, MODEL SR64
(2)	KICKPLATE	HIAWATHA, MODEL KP834-32D
(1)	COAT HOOK	MILLS, MODEL FT6519, SUPPLIED BY WASHROOM ACCESSORIES VENDOR, MOUNT T.O. HOOK AT 47 1/2" AFF


DOOR FRAME

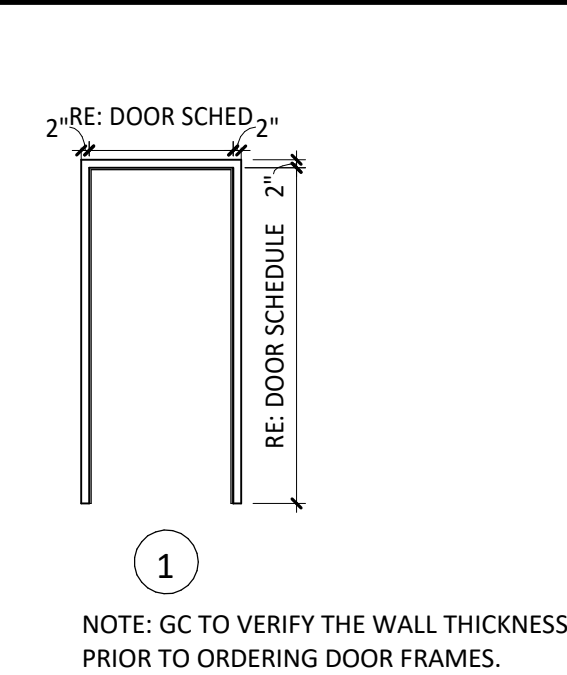


CUSTOM WOOD PULL

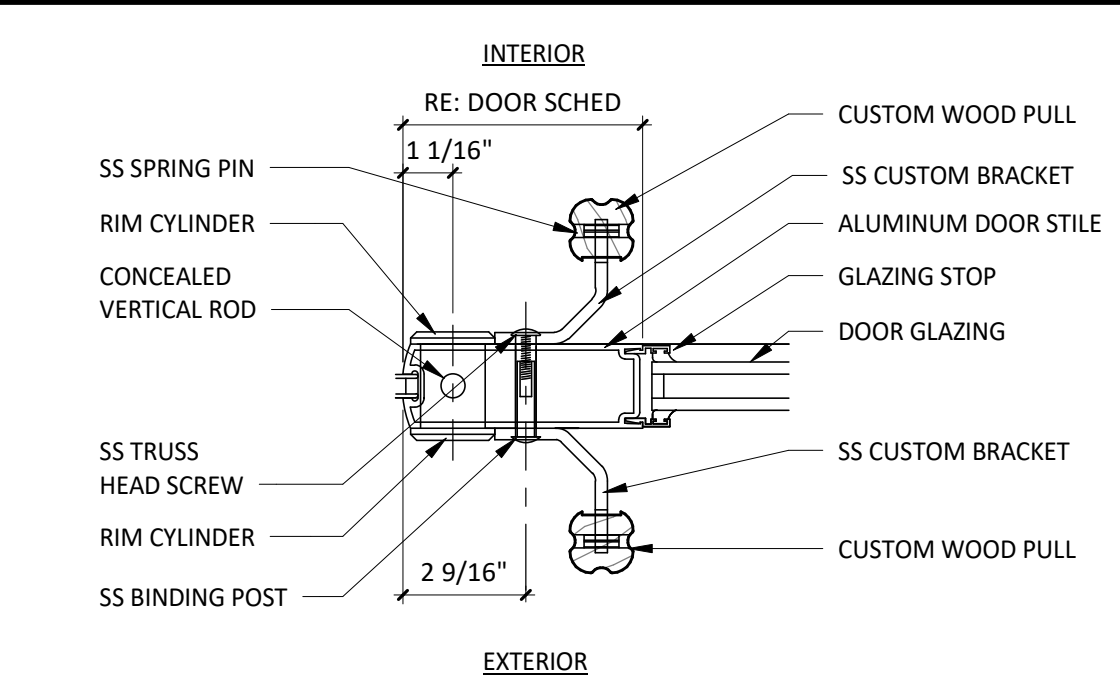


SILL FLASHING

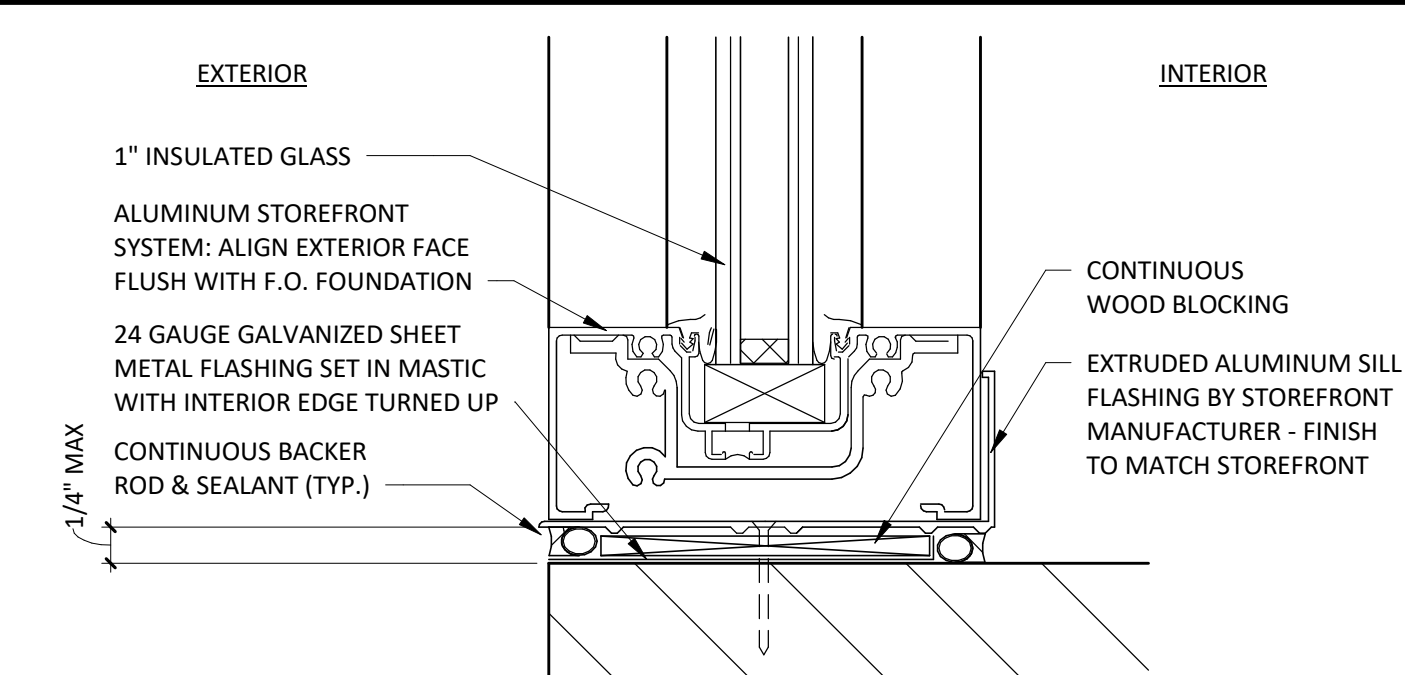

DOOR TYPES

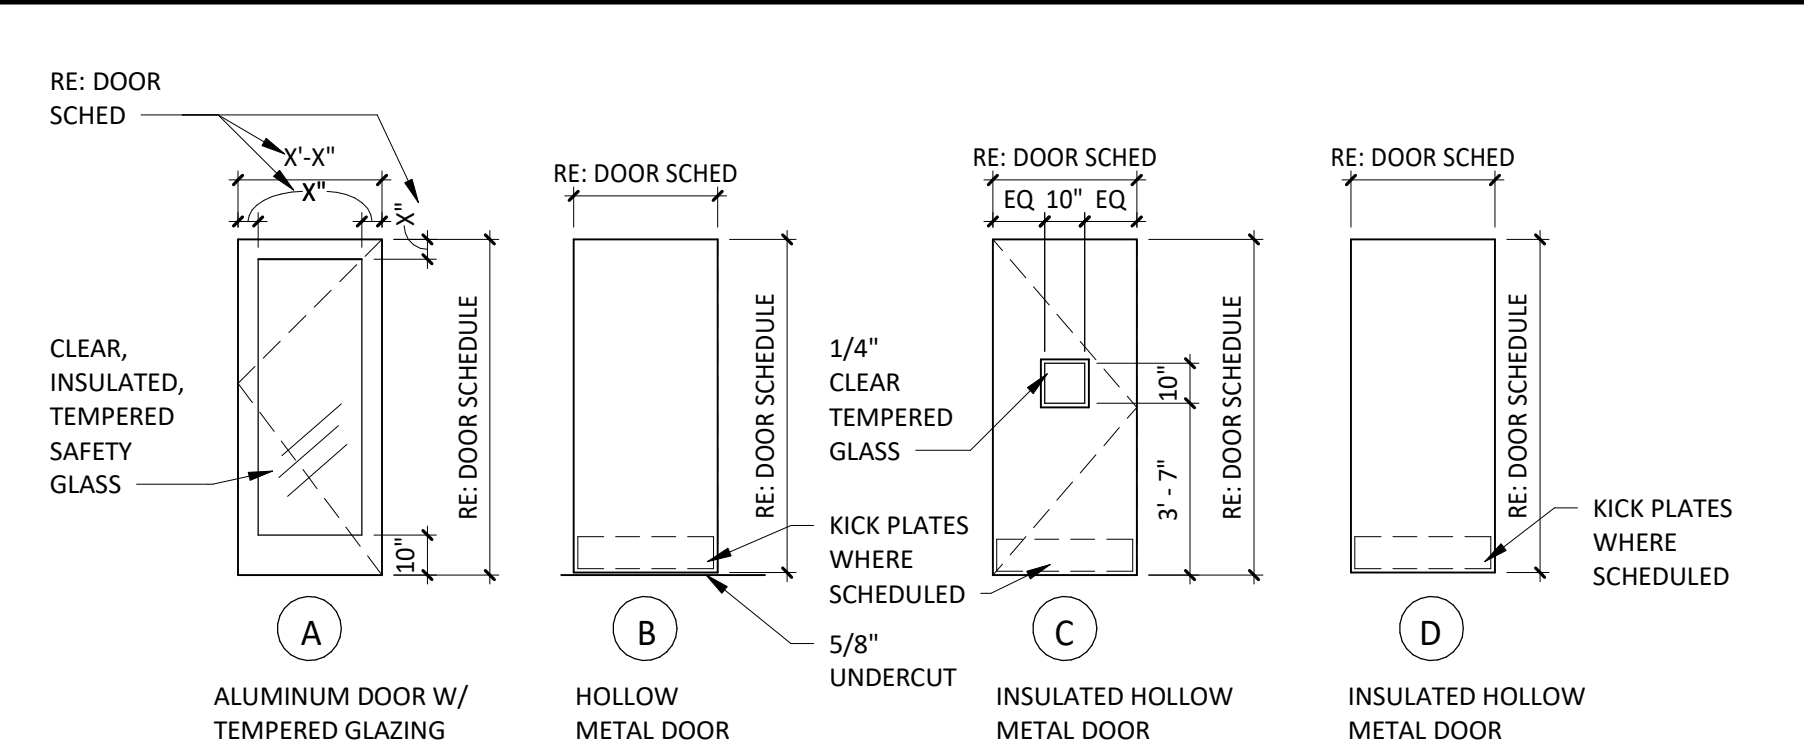

DOOR CLOSER

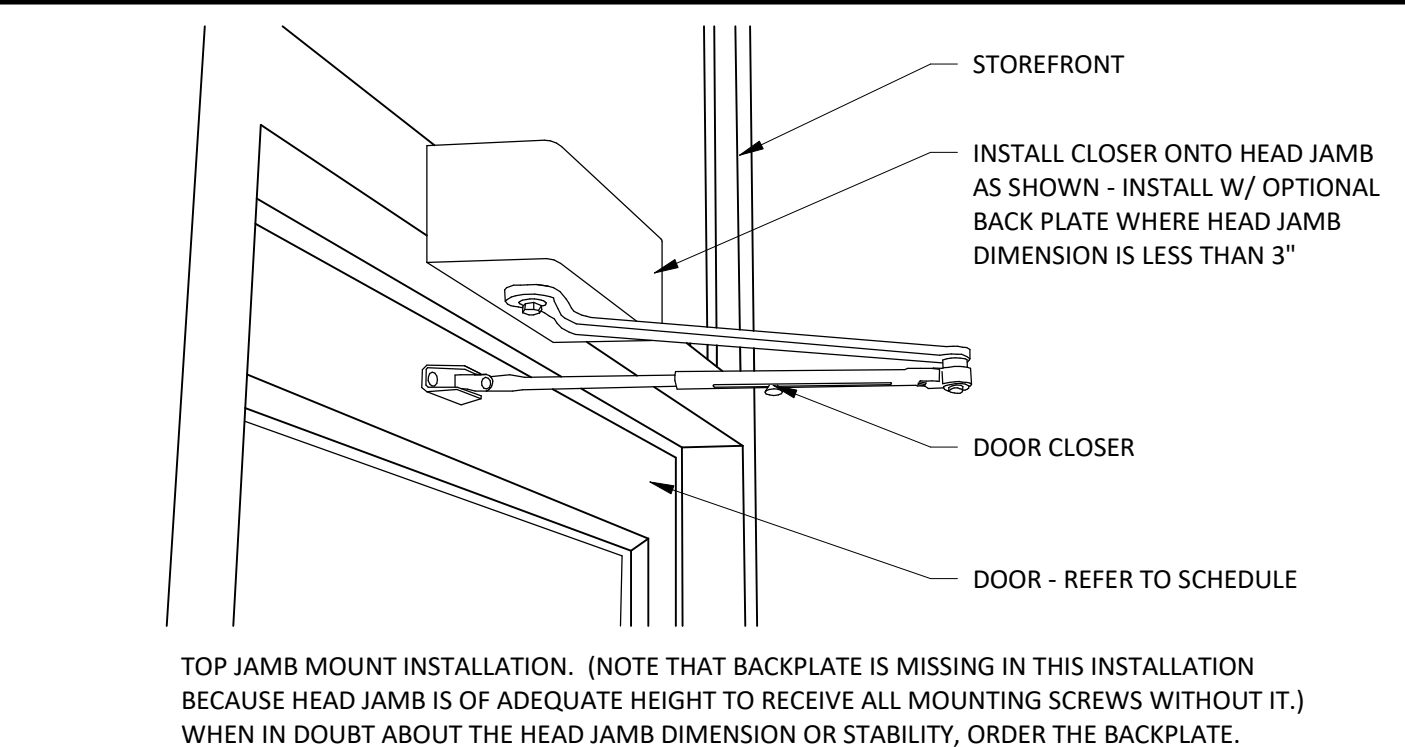

CLIENT:



CHIPOTLE MEXICAN GRILL, INC.
PO BOX 182966
COLUMBUS, OH 43218-2966
TELEPHONE: (614) 318-2682
INTERNET: WWW.CHIPOTLE.COM

COPYRIGHT 2024
THIS DRAWING IS AN INSTRUMENT OF SERVICE AND AS SUCH REMAINS THE PROPERTY OF CHIPOTLE MEXICAN GRILL, INC. PERMISSION FOR USE OF THIS DOCUMENT IS LIMITED AND CAN BE EXTENDED ONLY BY WRITTEN AGREEMENT WITH CHIPOTLE MEXICAN GRILL, INC.

PROJECT INFORMATION:

STORE NO.: 4757
"ANDERSON IN"
S SCATTERFIELD RD & 59TH STREET
ANDERSON, IN 46013

SEAL:



July 25, 2024
MATTHEW M. WILKUS
LICENSE #A11700110
(EXPIRES 12/31/2024)

PROJECT NO. 2022-0494
DRAWN BY RDB
CHECKED BY


ISSUE RECORD:
12/12/2023 PERMIT SET
06/19/2024 BID SET
07/24/2024 CONSTRUCTION SET

REVISIONS:
2 07/24/2024 CONSTRUCTION SET


TITLE:
DOOR &
HARDWARE
SCHEDULE

SHEET NUMBER:


A601

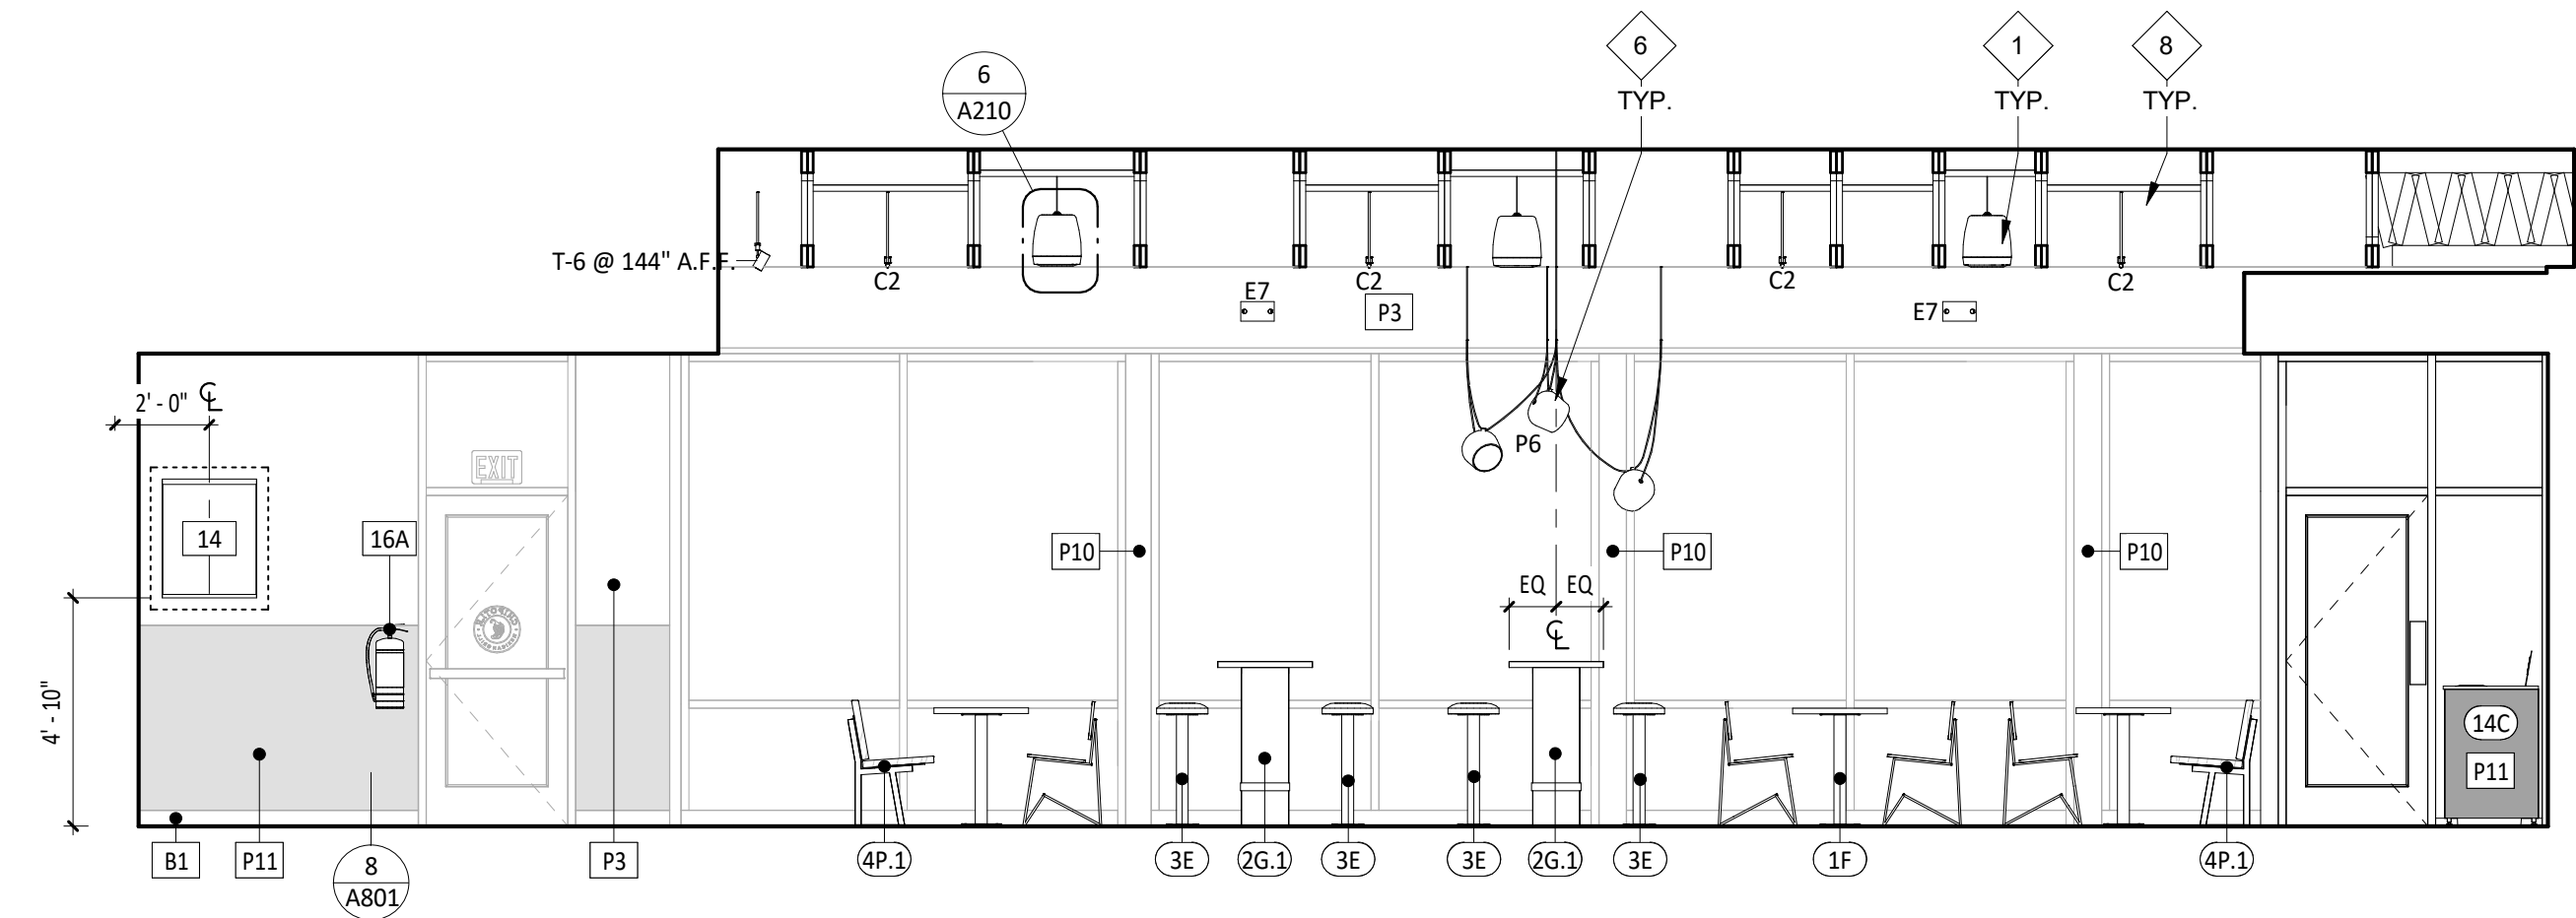


1 DINING ELEVATION
SCALE: 1/4" = 1'-0"

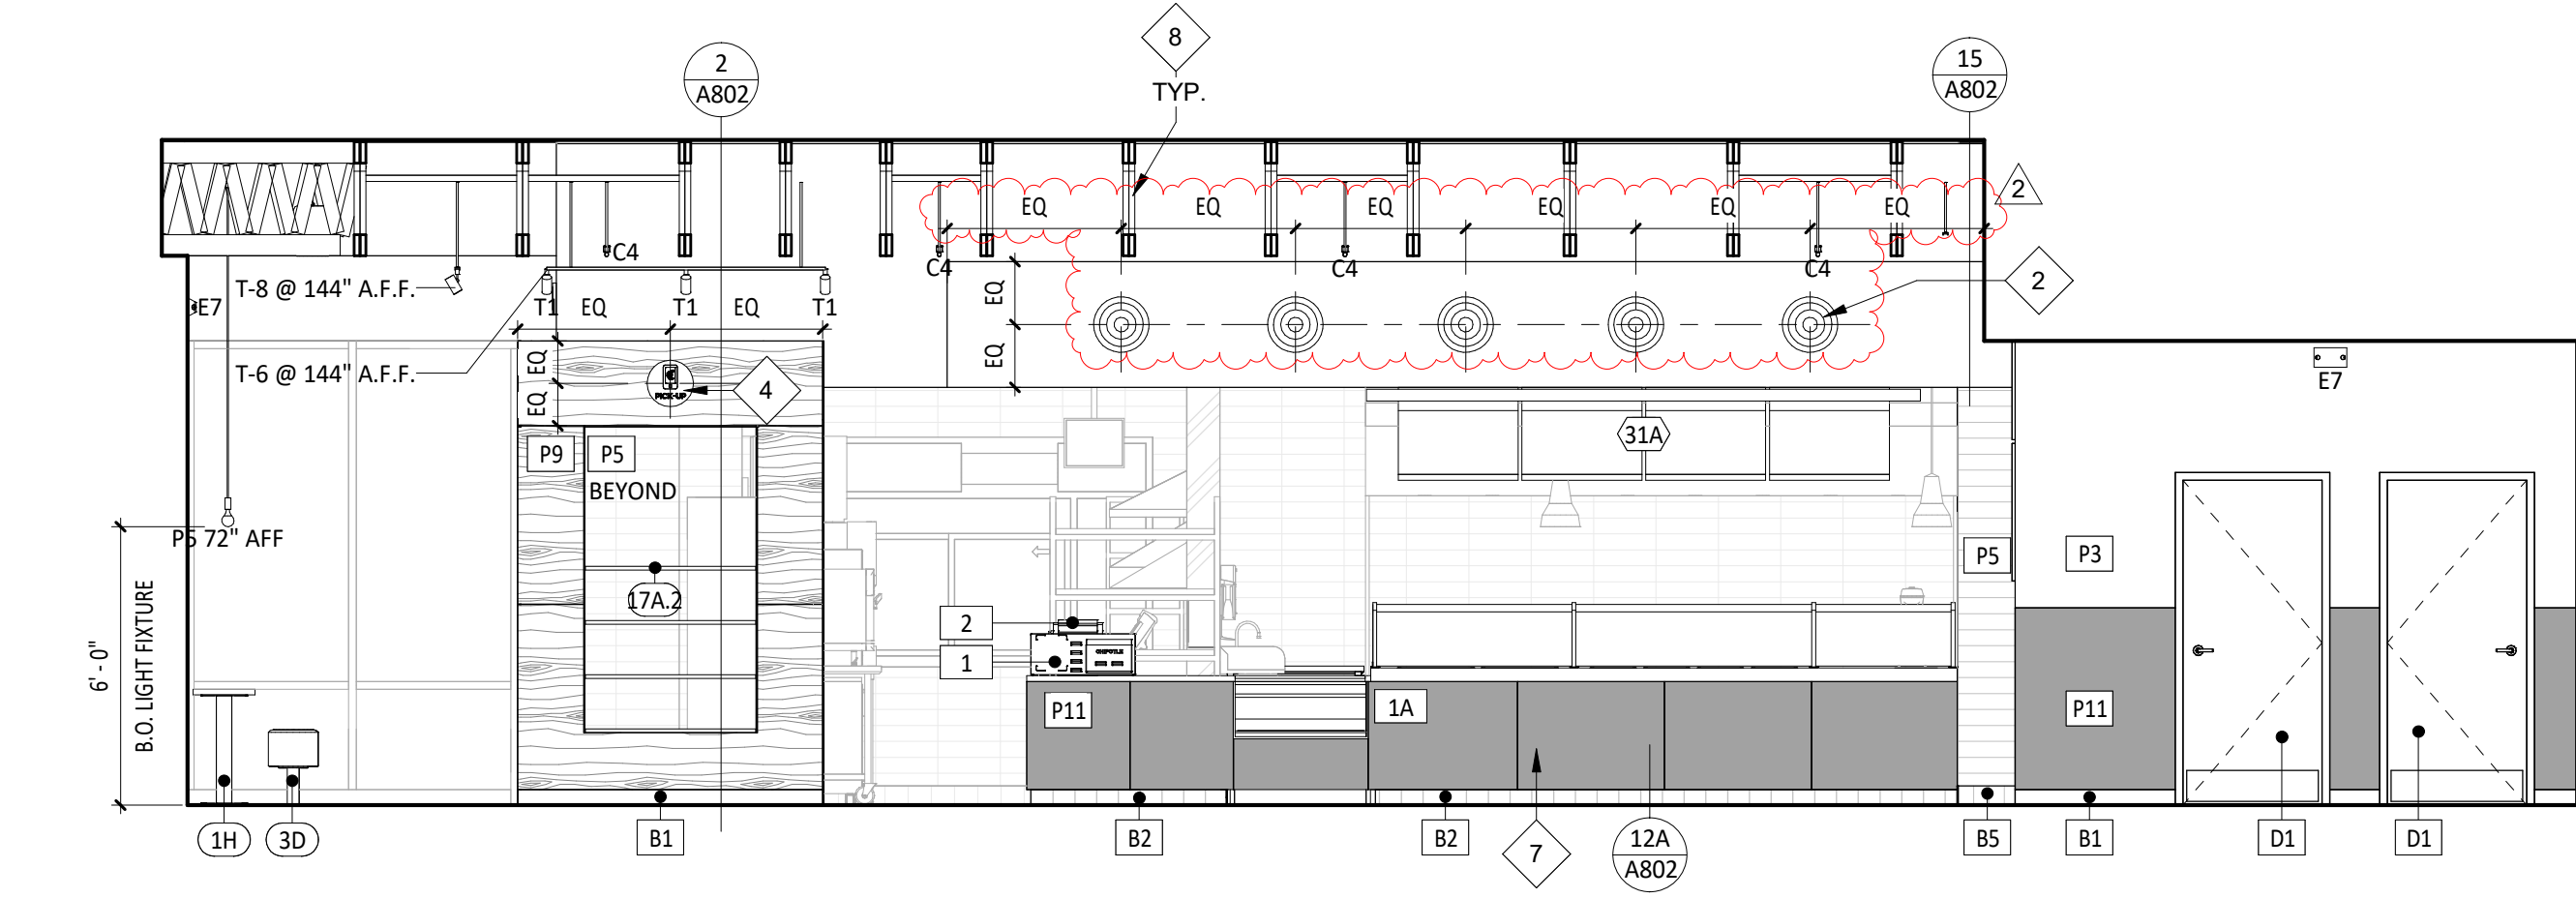


3 DINING ELEVATION
SCALE: 1/4" = 1'-0"

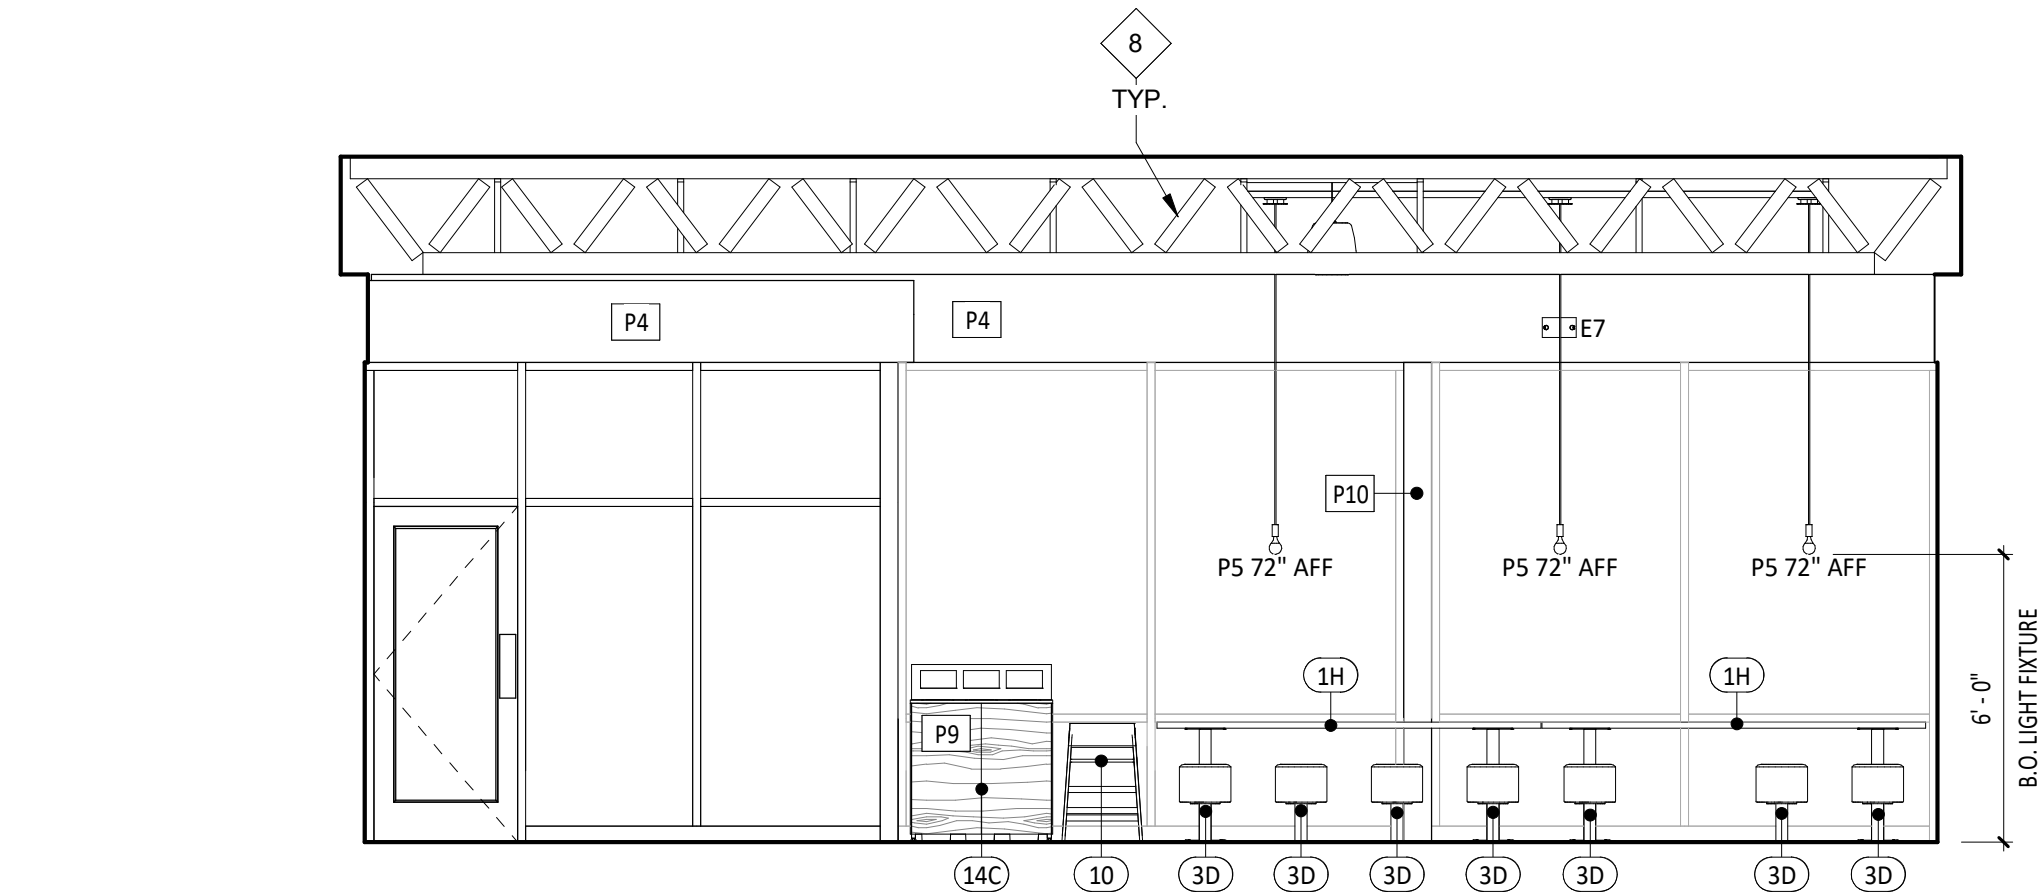

5 DINING ELEVATION
SCALE: 1/4" = 1'-0"

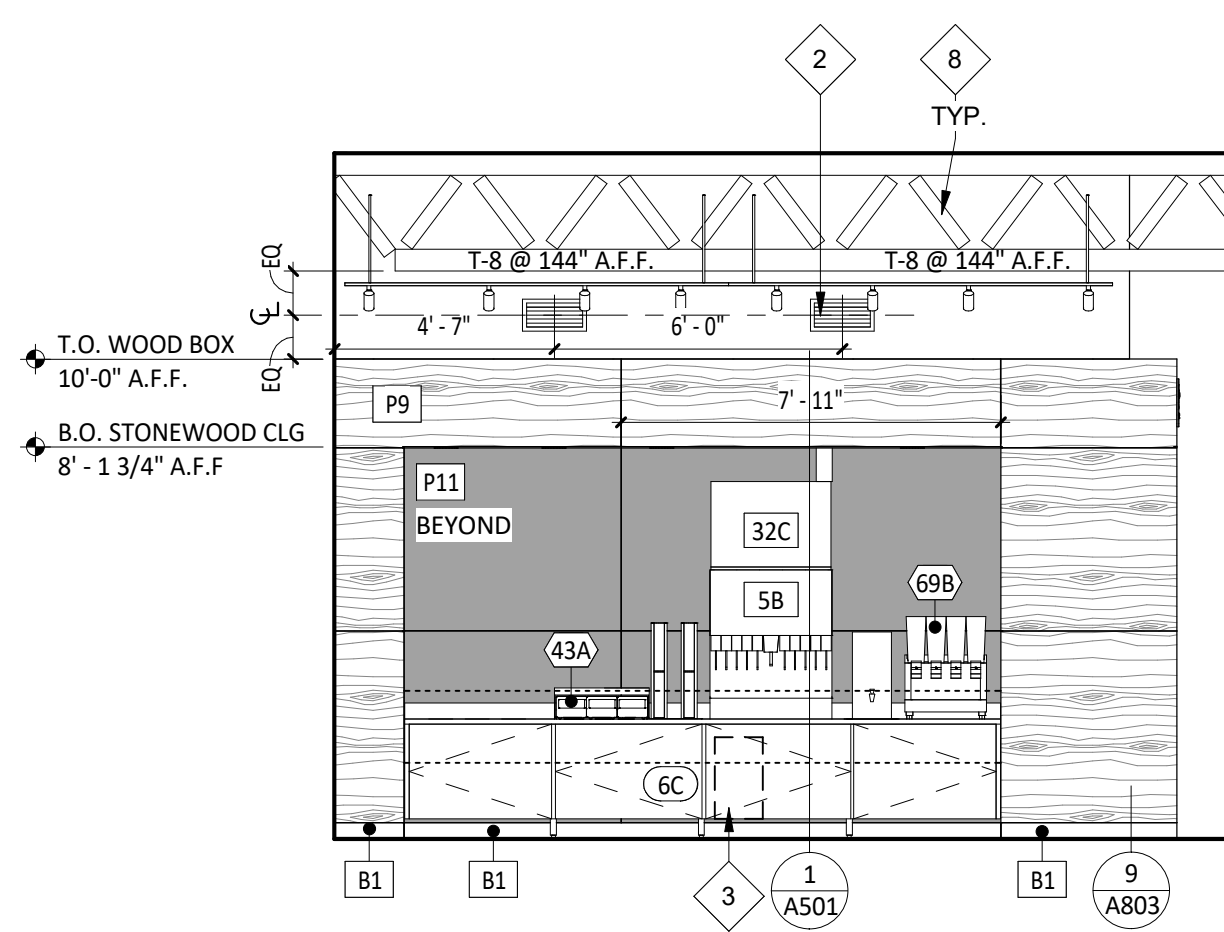

2 DINING ELEVATION
SCALE: 1/4" = 1'-0"

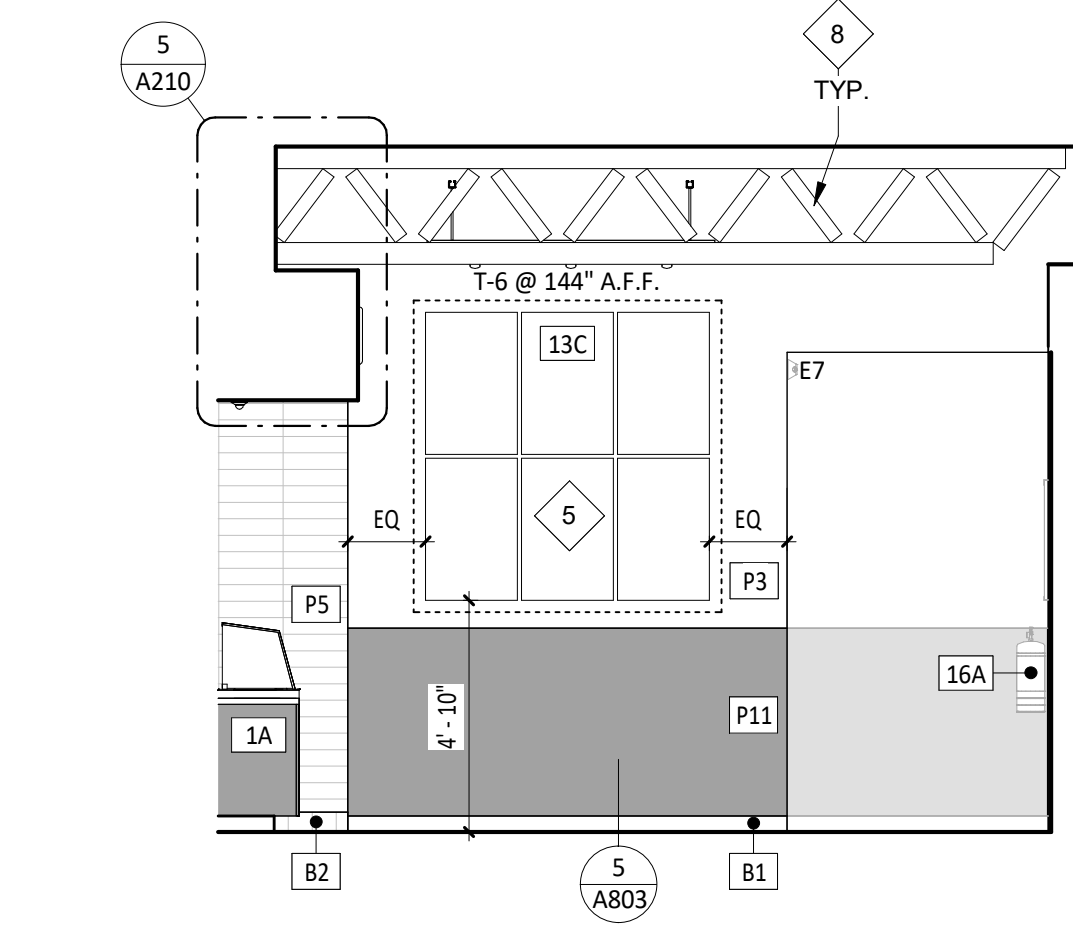

4 DINING ELEVATION
SCALE: 1/4" = 1'-0"

GENERAL NOTES - INT. ELEV.

- A. REFER TO SHEET A131 FOR EQUIPMENT LIST AND FURNITURE SCHEDULE.
B. PROVIDE FULL HEIGHT BLOCKING IN WALL FOR ALL SHELVING, TYP.
C. REFER TO A120 FOR FINISH SCHEDULE.
D. REFER TO A201 AND ELECTRICAL DRAWINGS FOR LIGHT FIXTURE SCHEDULE.

ELEVATION LEGEND

- DENOTES WOOD BLOCKING IN WALL BEHIND WALL
MOUNTED OBJECT U.N.O.

KEYNOTE LEGEND

- 1 SPEAKER LOCATION - REFER TO A201 FOR ADDITIONAL INFORMATION.
2 DUCTWORK SHOWN FOR REFERENCE ONLY - REFER TO MECHANICAL DRAWINGS FOR ALL FINAL DUCTWORK LOCATIONS.
3 SODA CHASE BEYOND - REFER TO PLUMBING DRAWINGS FOR ADDITIONAL INFORMATION.
4 PICK-UP SIGN BY TENANT SIGNAGE VENDOR - INSTALLED BY GENERAL CONTRACTOR - COORDINATE REQUIRED BLOCKING REQUIREMENTS.
5 6 - PANEL ARTWORK LOCATION.
6 BARNLIGHT FIXTURES TO BE CENTERED OVER HIGHTOP TABLE - REFER TO A211 FOR ADDITIONAL INFORMATION.
7 STONEWOOD PANEL PROVIDED BY MILLWORK VENDOR, INSTALLED BY GC.
8 EXISTING STRUCTURE TO REMAIN UNPAINTED - REFER TO A140 AND A201 FOR ADDITIONAL INFORMATION.



CLIENT:



CHIPOTLE MEXICAN GRILL, INC.
PO BOX 18266
COLUMBUS, OH 43218-2666
TELEPHONE: (614) 318-2662
INTERNET: WWW.CHIPOTLE.COM

COPYRIGHT 2024
THIS DRAWING IS AN INSTRUMENT OF SERVICE AND AS SUCH REMAINS THE PROPERTY OF CHIPOTLE MEXICAN GRILL, INC. PERMISSION FOR USE OF THIS DOCUMENT IS LIMITED AND CAN BE EXTENDED ONLY BY WRITTEN AGREEMENT WITH CHIPOTLE MEXICAN GRILL, INC.

PROJECT INFORMATION:

STORE NO.: 4757
"ANDERSON IN"
S SCATTERFIELD RD & 59TH STREET
ANDERSON, IN 46013

SEAL:



July 25, 2024

MATTHEW M. WILKUS
LICENSE #A11700110
(EXPIRES 12/31/2024)

PROJECT NO. 2022-0494

DRAWN BY RDB

CHECKED BY

ISSUE RECORD:

12/12/2023 PERMIT SET

06/19/2024 BID SET

07/24/2024 CONSTRUCTION SET

REVISIONS:















2 07/24/2024 CONSTRUCTION SET

TITLE:

ELEVATIONS -
INTERIOR DINING

SHEET NUMBER:

A701

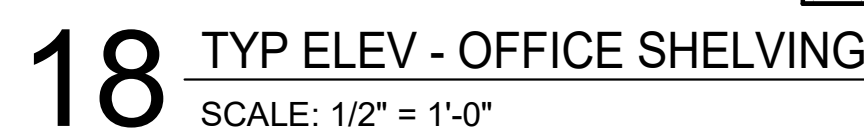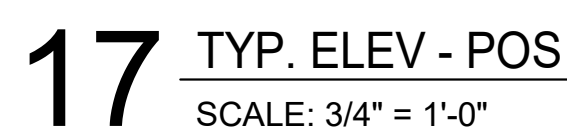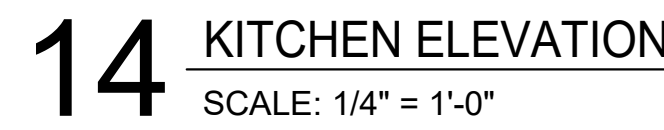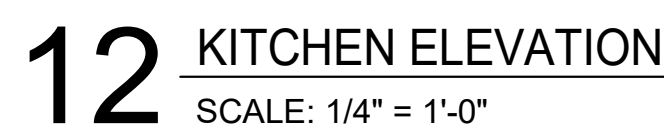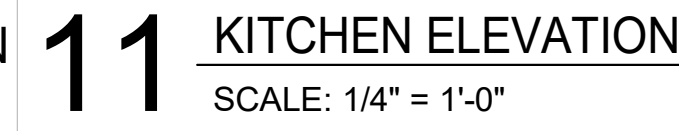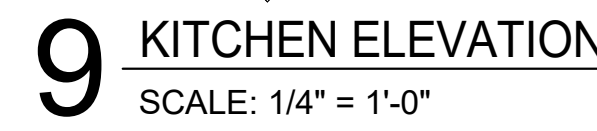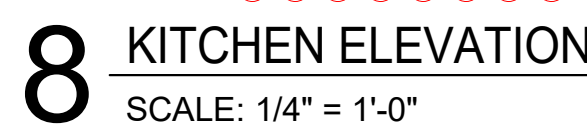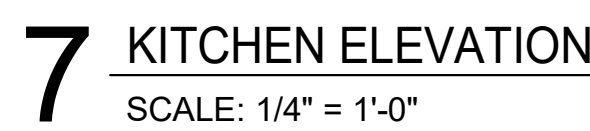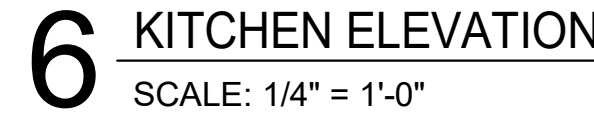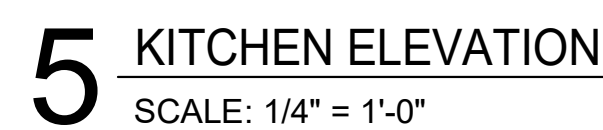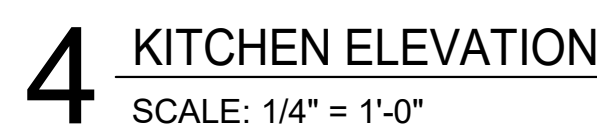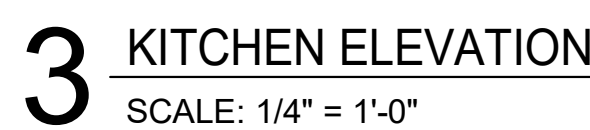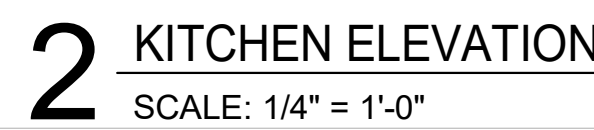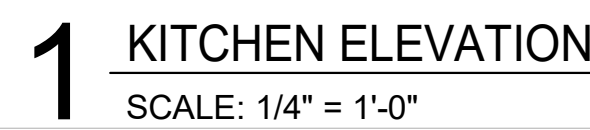

A702

RESTROOM ACCESSORIES


ITEM #	DESCRIPTION	MANUF	MODEL	QTY	PROVIDED BY	INSTALLED BY	UTILITY				MOUNTING HEIGHT	REMARKS
							ELEC	GAS	WATER	SEWER		
1A	Grab Bar - 36in	ASI	3501-36	2	WA	GC					34" AFF to Centerline of Gaspng Surface	Provide Plywood Blocking to Mount to Wall
1B	Grab Bar - 42in	ASI	3501-42	2	WA	GC					34" AFF to Centerline of Gaspng Surface	Provide Plywood Blocking to Mount to Wall
1C	Grab Bar - 18in	ASI	3501-18	2	WA	GC					40" AFF to Centerline of Bottom Return	Provide Plywood Blocking to Mount to Wall
3	Vandal Proof Mirror	Sentry Mirror	20" x 30" Vandal Proof Mirror	2	TS	GC					Bottom Edge of Reflecting Surface at 40" AFF	Provide Plywood Blocking to Mount to Wall
5	Touch-Free Soap Dispenser	Purell	CS8	2	WA	GC					47 1/2" AFF To Top Of Dispenser	
7	Recessed Toilet Paper Dispenser	ASI	0031	2	WA	GC					29" AFF to Top of Unit	Recess Mounted in Wall - Rough Opening: 6 1/4"W X 12 1/4"H X 3 3/8"D Top of Rough Opening: 29 1/4" AFF Provide Toggle Bolts to Mount to Wall
8	Utility Shelf	ASI	0692	2	WA	GC					46" AFF To Top Of Shelf	
9	Recessed Convertible Paper Towel Dispenser and Waste Receptacle, Recess Mounted in Wall	Bobrick	B-3944	2	WA	GC					Bottom of Unit at Top of Base, Bottom of Dispenser to be at 40" AFF, Recess Mounting In Wall	Rough Opening: 16"W x 54 3/4"H x 4" D. Provide Plywood Blocking to Mount to Wall
12	Napkin Disposal - Recessed	ASI	0473	2	WA	GC					Top of Rough Opening @ 29" AFF	Recess Mounted in Wall - Rough Opening: 11 1/4"W X 15 3/4"H X 4"D
14	Restroom Hand Sink	SEE MEP	SEE MEP	2	GC	GC					Mount Bottom of Front Edge Of The Sink At Exactly 29" AFF	
14.1	Restroom Hand Sink Faucet	T&S	EC-3102-TMV-LF-05	2	KES	GC						To Be Furnished With .5 GPM Aerator Installed. Thermostatic mixing valve is also included.
15	Hand Sanitizer Dispenser	Purell	ES8	2	WA	GC					Align T.O. Unit With T.O. Soap Dispenser	
16a	Surface Mounted Horizontal Baby Changing Station	Koala Care	KB200-05	2	WA	GC					Mount Bottom of Open Changing Bed at Exactly 27" AFF	GC to Provide adequate blocking to support the baby changing equipment. Blocking shall be installed in such a manner to not damage or compromise the rated assembly of the existing wall construction

GENERAL NOTES - RESTROOM


- A. ALL DIMENSIONS ARE TO FACE OF STUD UNLESS OTHERWISE NOTES.
- B. REFER TO A801 FOR FINISH DETAIL NOTES.
- C. ALL ACCESSORIES SHALL BE AS MANUFACTURED BY AMERICAN SPECIALTIES INC OR TENANT-APPROVED EQUIVALENT UNLESS DESIGNATED OTHERWISE. PROVIDE SOLID FRT WOOD BLOCKING AS NECESSARY FOR INSTALLATION PER MANUFACTURER'S RECOMMENDATIONS. SEE SHEET G002 FOR ACCESSIBILITY GUIDELINES & MOUNTING HEIGHT REQUIREMENTS.
- D. REFER TO A120 FOR FINISH SCHEDULE.
- E. REFER TO A201 AND ELECTRICAL DRAWINGS FOR LIGHT FIXTURE SCHEDULE.

ELEVATION LEGEND


⬡ DENOTES WOOD BLOCKING IN WALL BEHIND WALL MOUNTED OBJECT U.N.O.

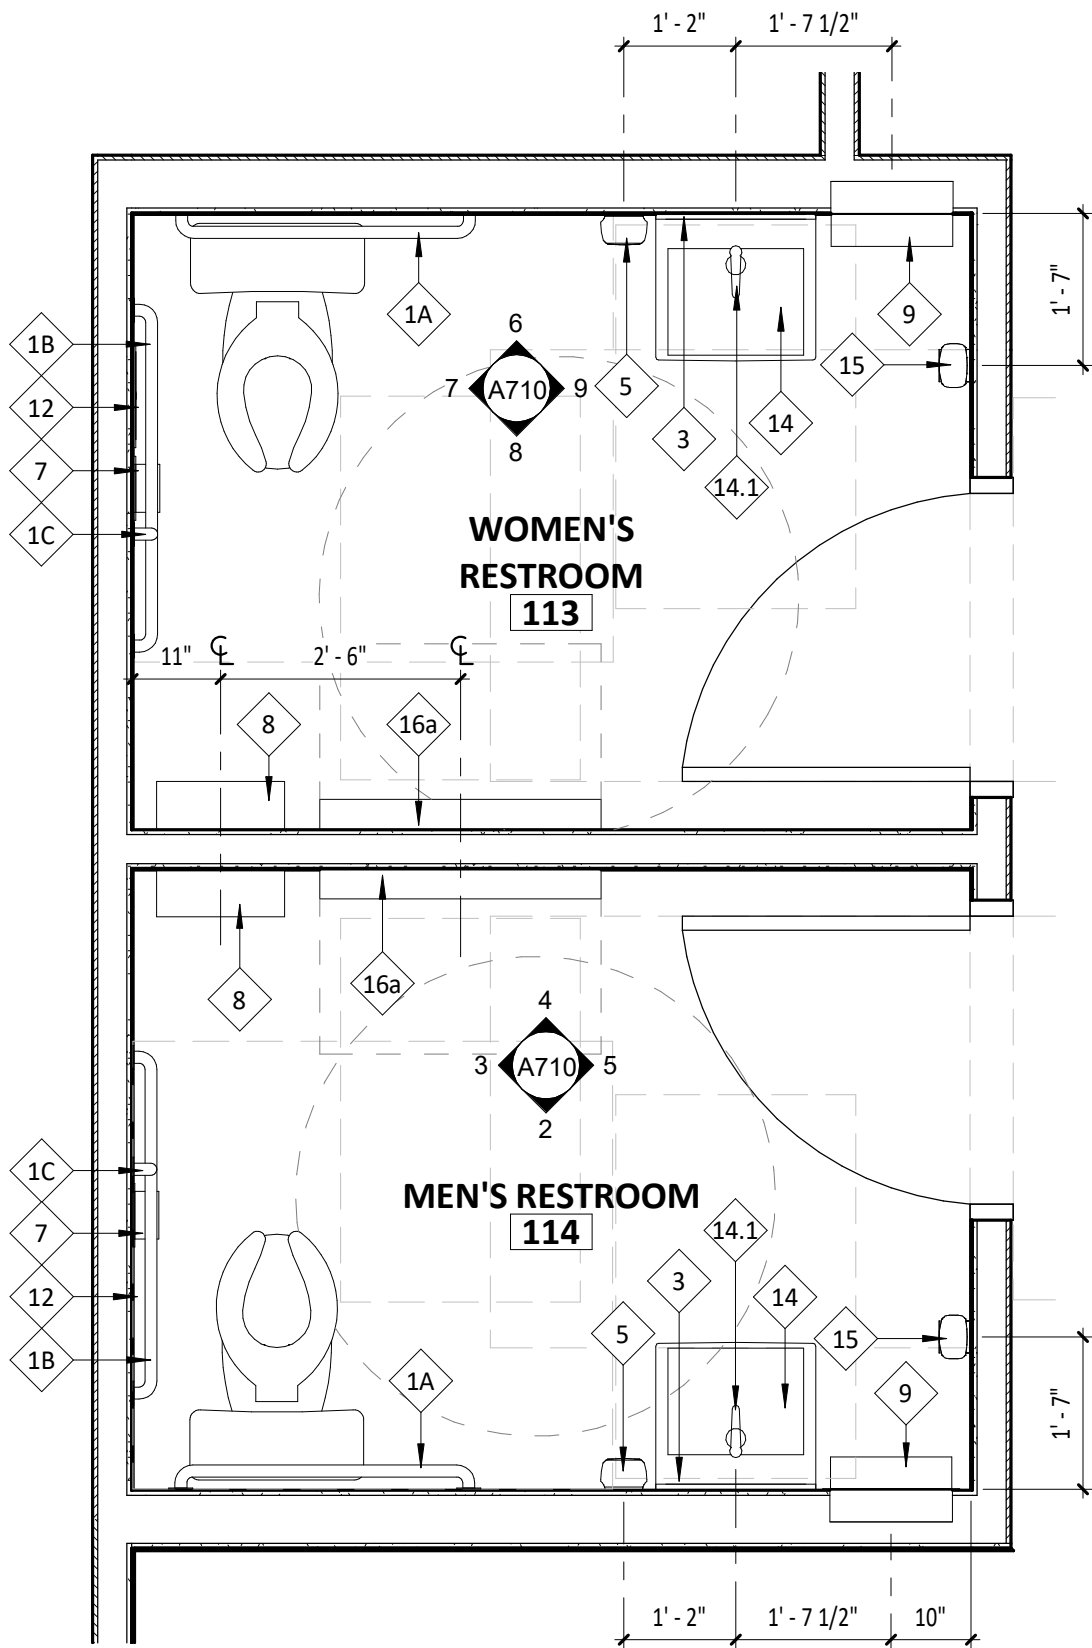


1 ENLARGED PLAN
SCALE: 1/2" = 1'-0"

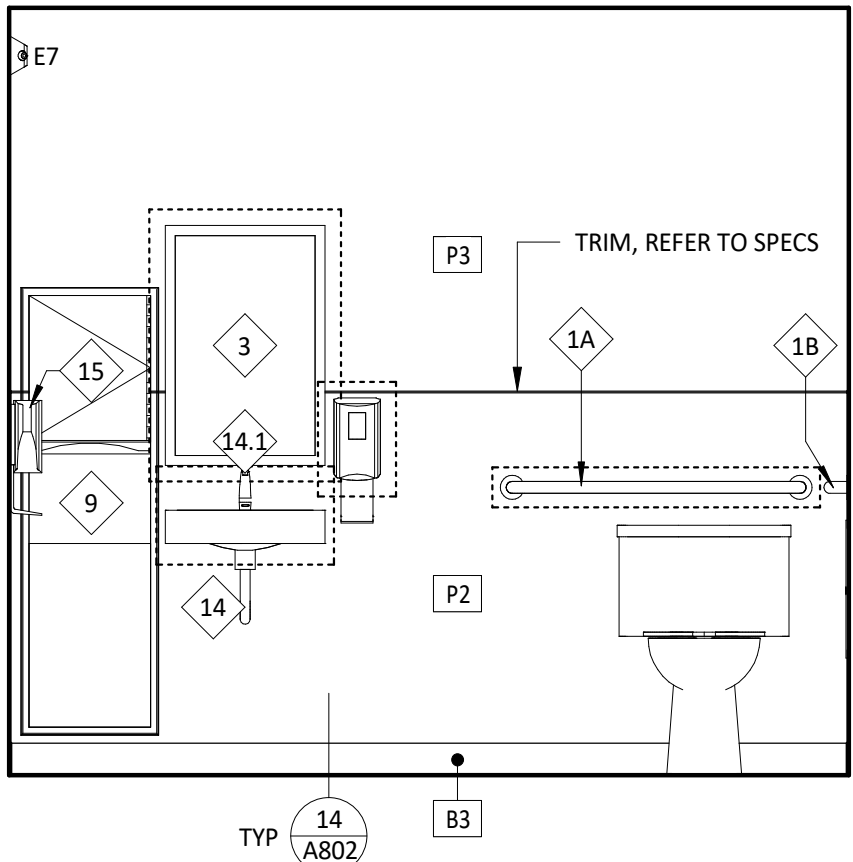


2 MEN'S RESTROOM
SCALE: 1/2" = 1'-0"

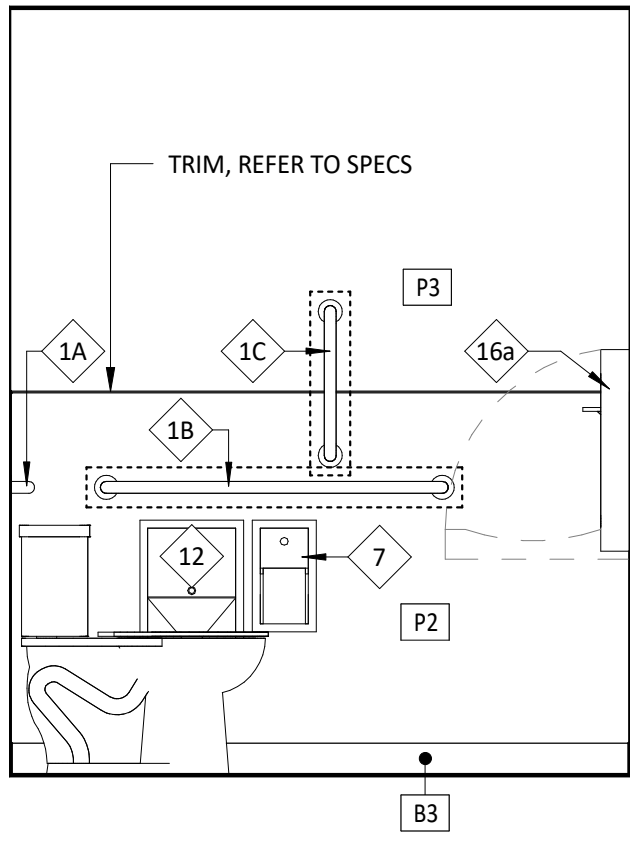


3 MEN'S RESTROOM
SCALE: 1/2" = 1'-0"

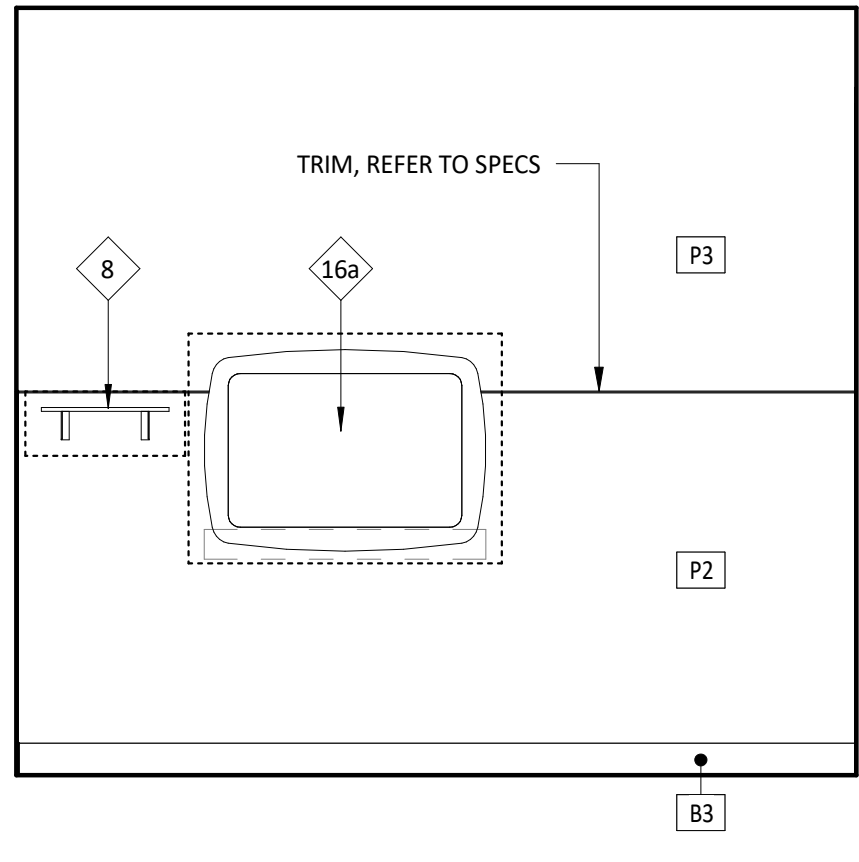


4 MEN'S RESTROOM
SCALE: 1/2" = 1'-0"

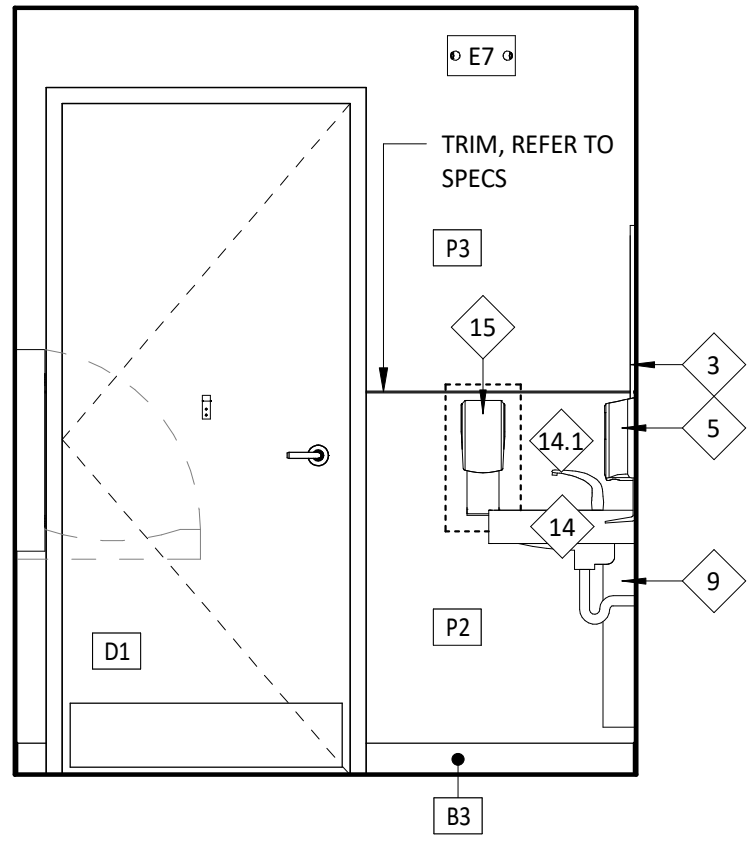


5 MEN'S RESTROOM
SCALE: 1/2" = 1'-0"

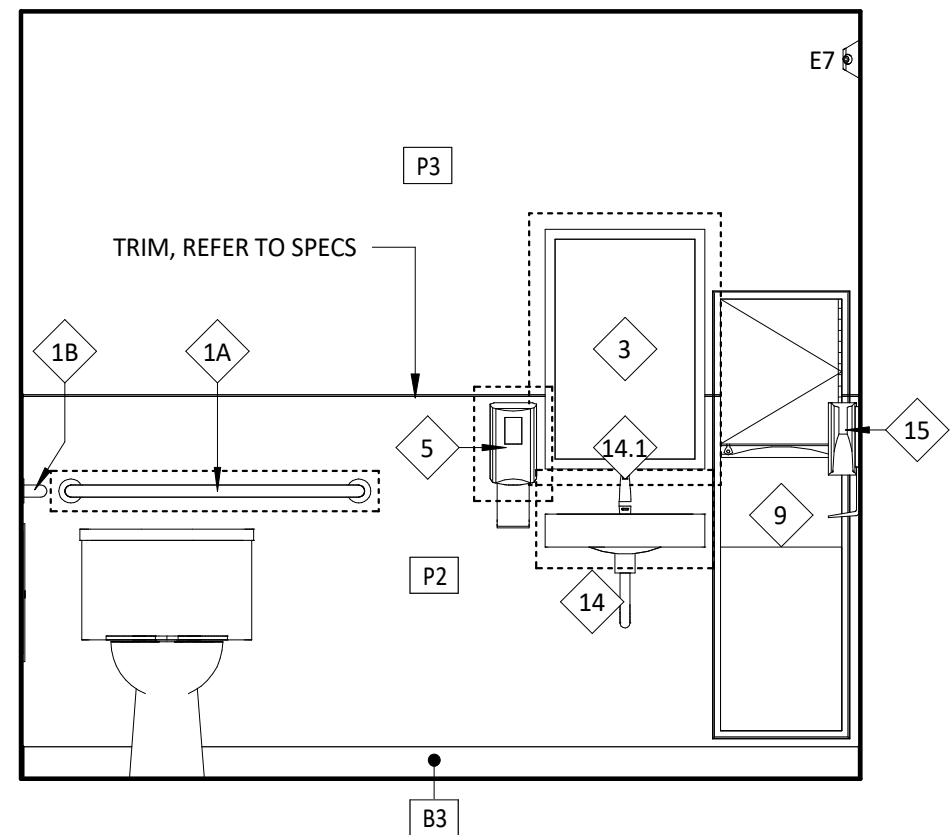


6 WOMEN'S RESTROOM
SCALE: 1/2" = 1'-0"

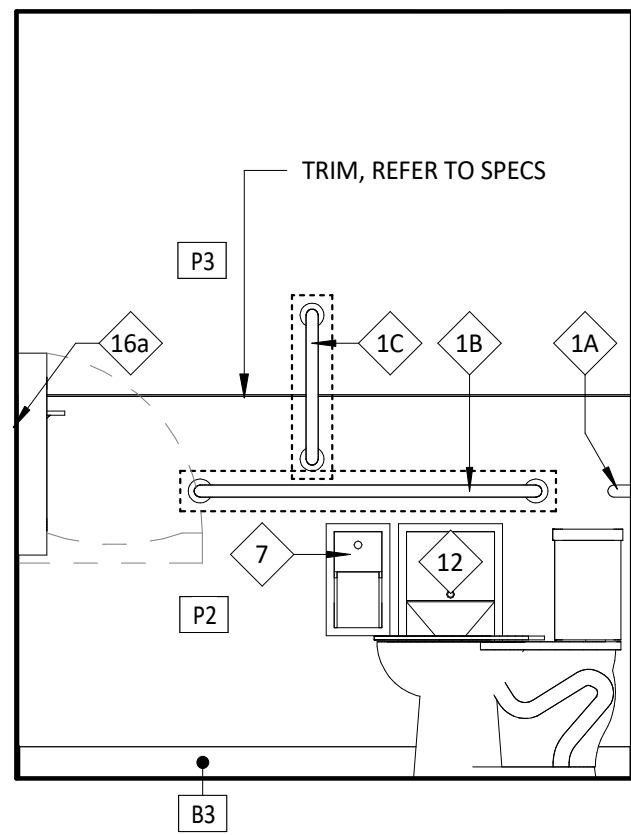


7 WOMEN'S RESTROOM
SCALE: 1/2" = 1'-0"

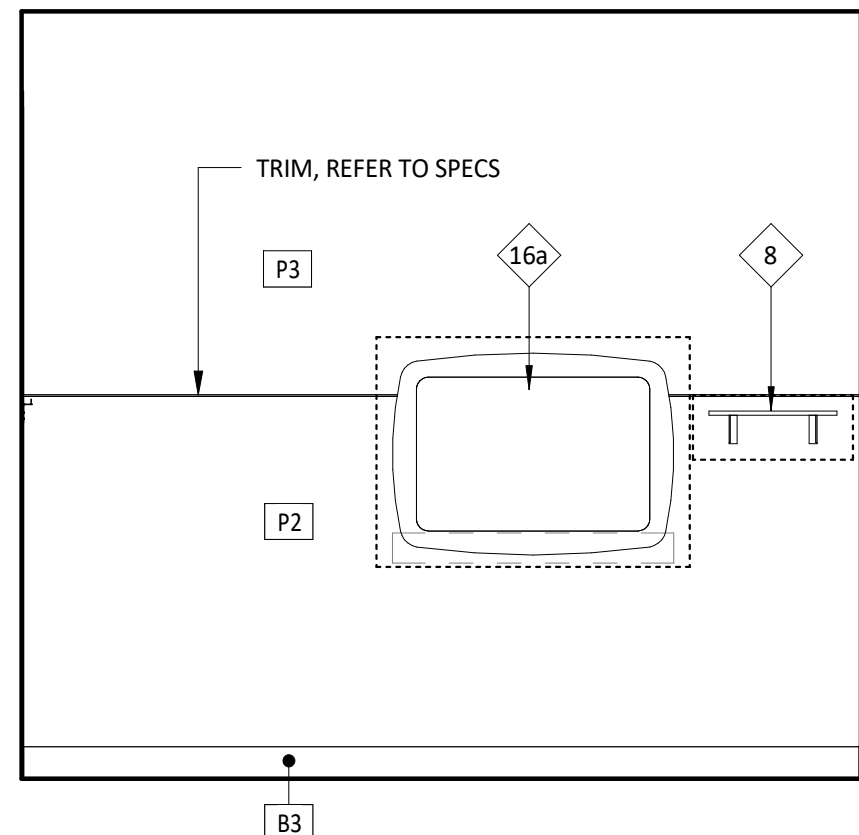


8 WOMEN'S RESTROOM
SCALE: 1/2" = 1'-0"

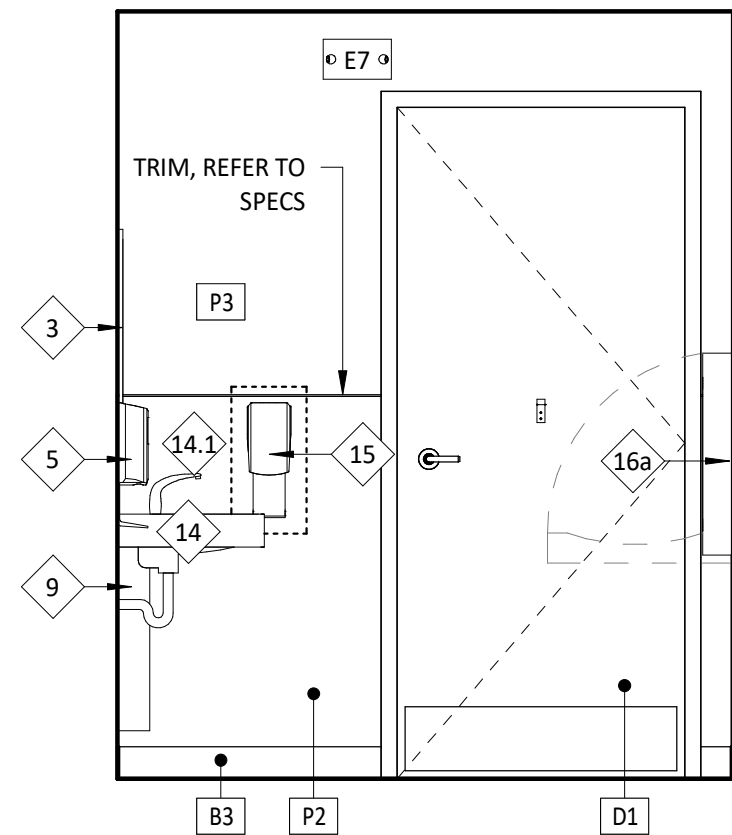

9 WOMEN'S RESTROOM
SCALE: 1/2" = 1'-0"

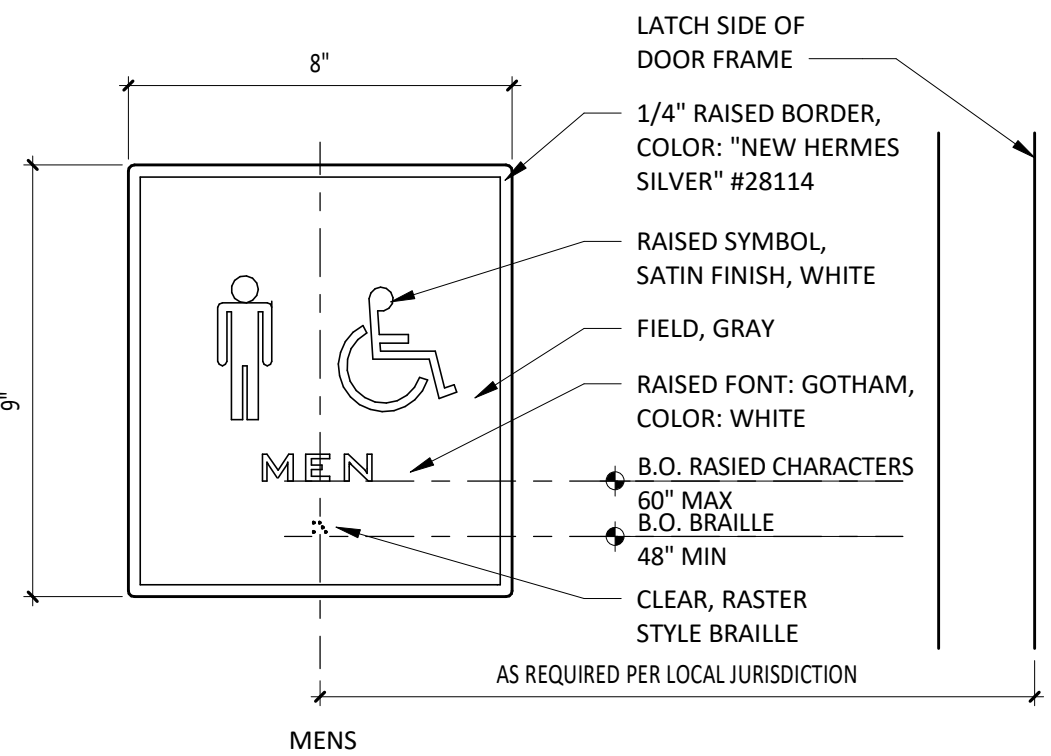

10 TYPICAL RESTROOM SIGNAGE
SCALE: 3" = 1'-0"

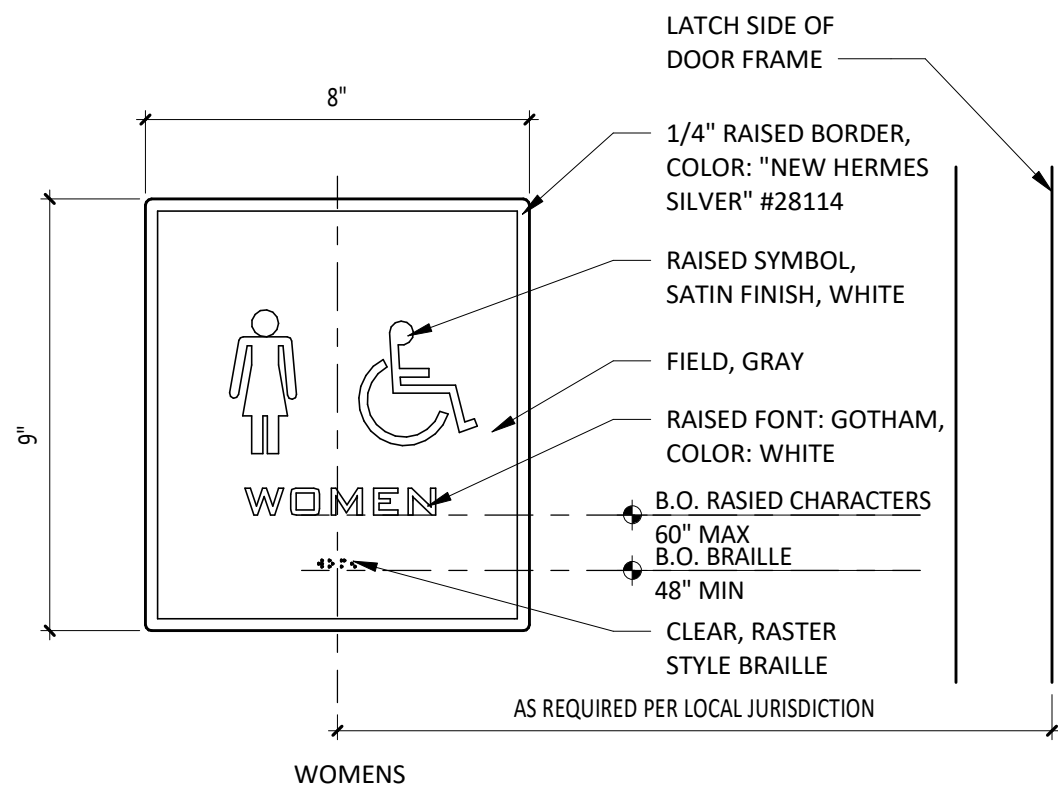

CLIENT:




COPYRIGHT 2024
THIS DRAWING IS AN INSTRUMENT OF SERVICE AND AS SUCH REMAINS THE PROPERTY OF CHIPOTLE MEXICAN GRILL, INC. PERMISSION FOR USE OF THIS DOCUMENT IS LIMITED AND CAN BE EXTENDED ONLY BY WRITTEN AGREEMENT WITH CHIPOTLE MEXICAN GRILL, INC.

PROJECT INFORMATION:

STORE NO.: 4757
"ANDERSON IN"
S SCATTERFIELD RD & 59TH STREET
ANDERSON, IN 46013

SEAL:

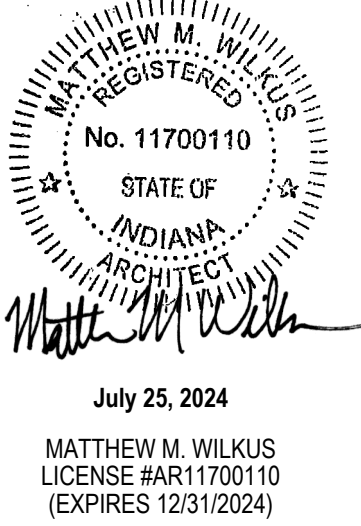

PROJECT NO. 2022-0494
DRAWN BY RDB
CHECKED BY


ISSUE RECORD:
12/12/2023 PERMIT SET
06/19/2024 BID SET
07/24/2024 CONSTRUCTION SET

REVISIONS:
1 05/20/2024 DB UPDATES


TITLE:
RESTROOM
DETAILS

SHEET NUMBER:


A710

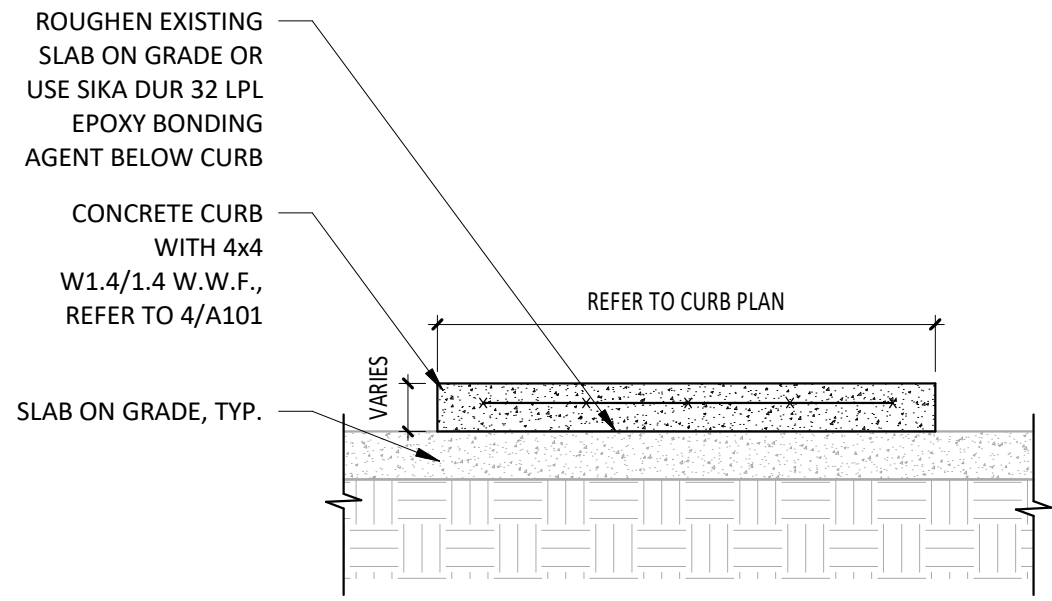


1 DETAIL @ CONCRETE CURB
SCALE: 3/4" = 1'-0"

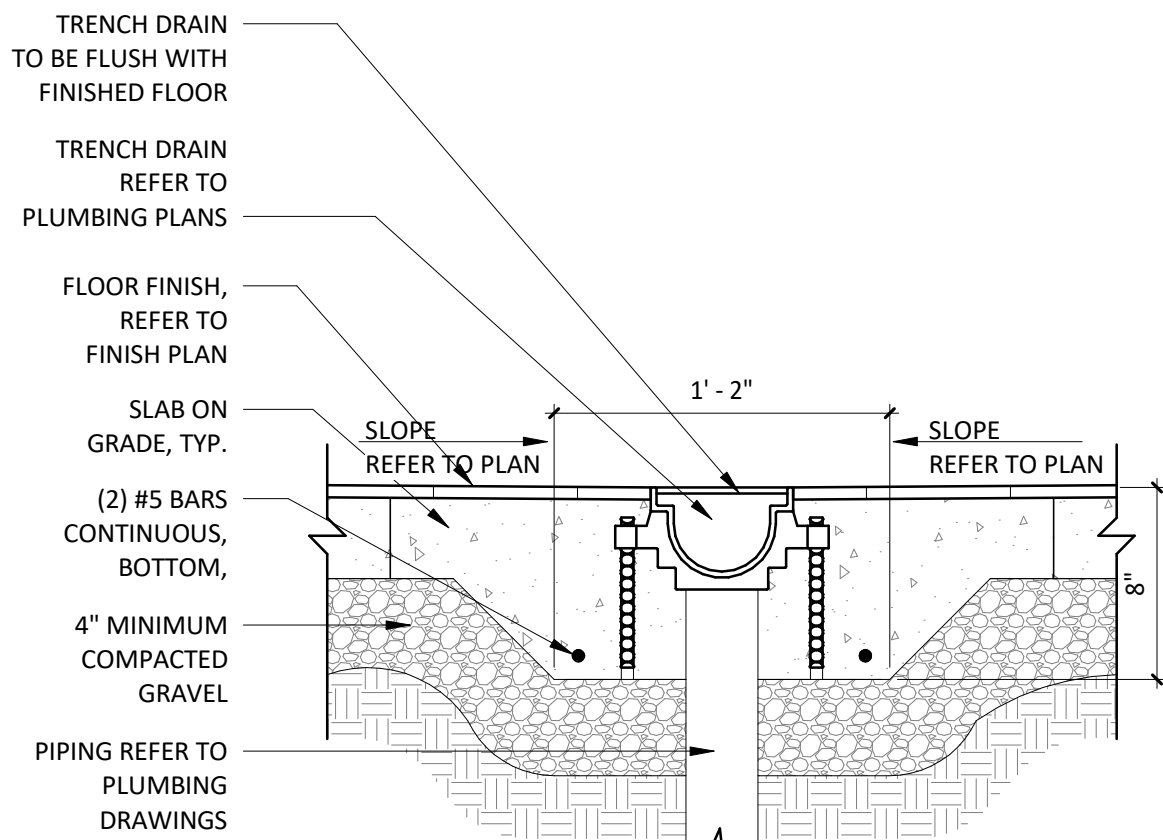


2 DETAIL @ TRENCH DRAIN
SCALE: 1 1/2" = 1'-0"

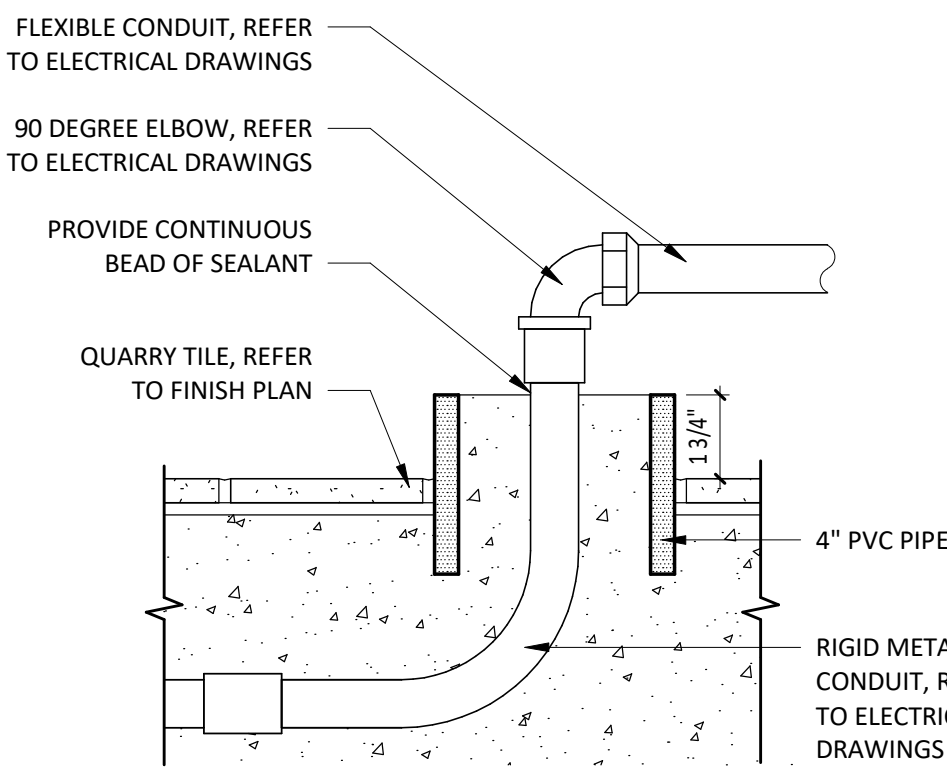


3 SECTION @ STUB LOCATION UNDER TABLES
SCALE: 3" = 1'-0"

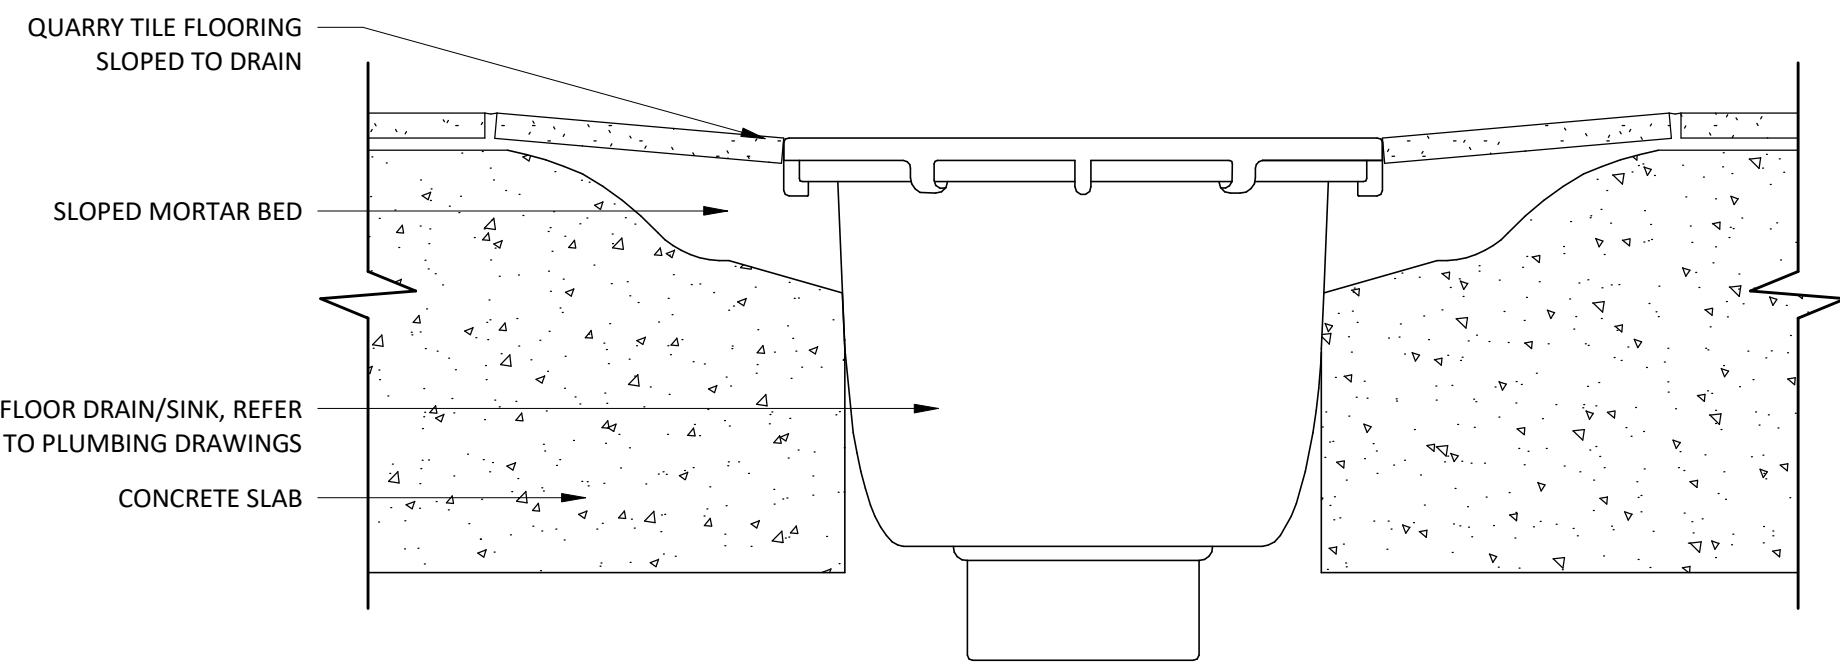


4 SECTION @ QT FLOOR DRAIN/SINK - TYP.
SCALE: 3" = 1'-0"

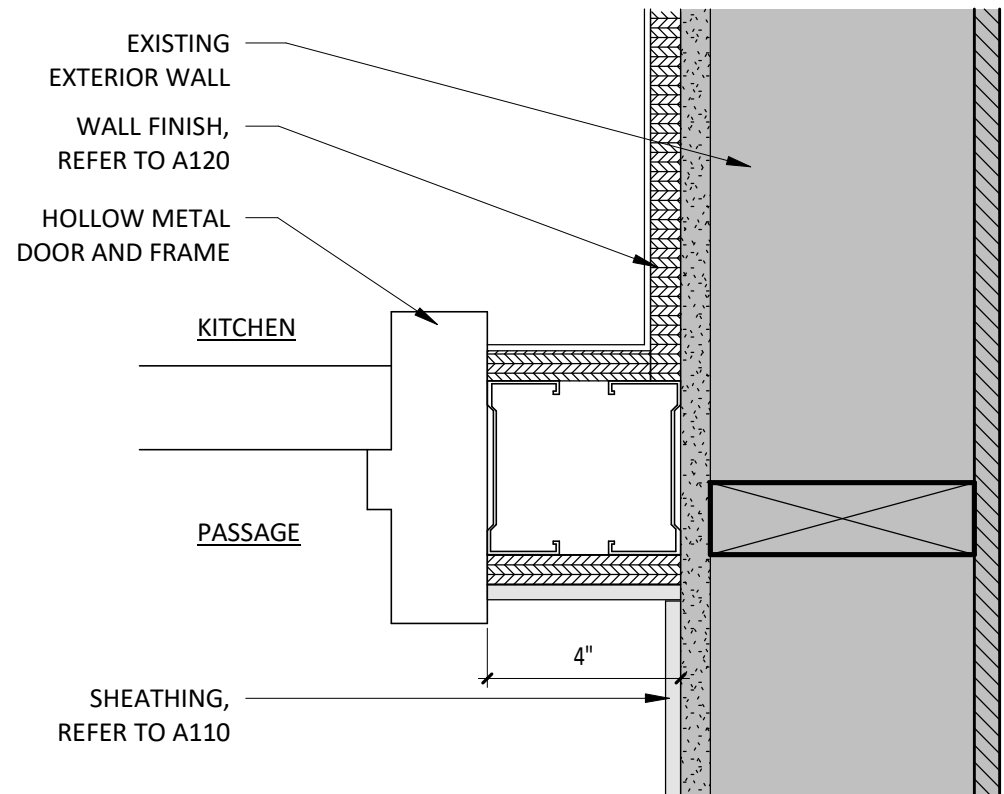


5 DETAIL @ DOOR JAMB
SCALE: 3" = 1'-0"

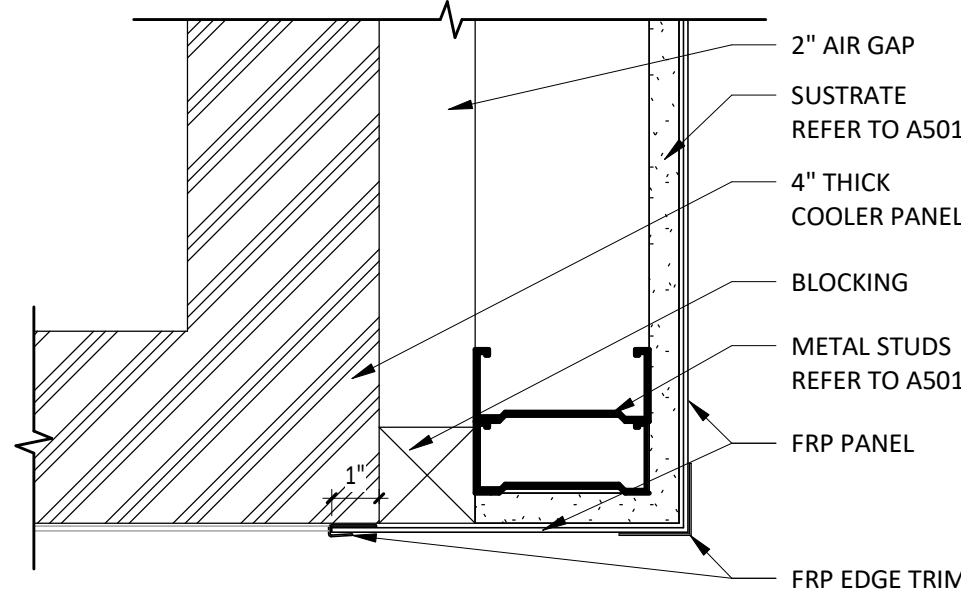


6 DETAIL @ FRP TO COOLER CLOSER STRIP
SCALE: 3" = 1'-0"

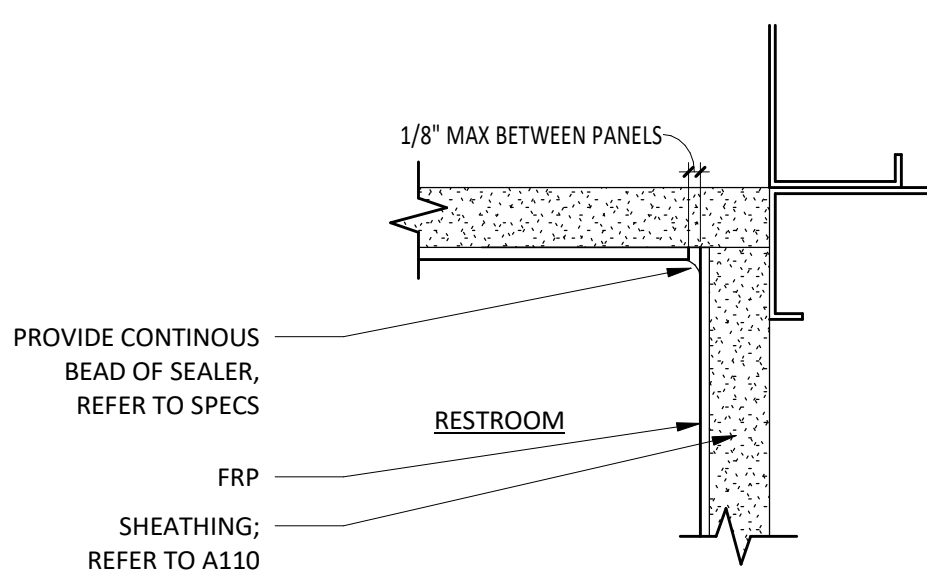


7 DETAIL @ RESTROOM FRP INSIDE CORNER
SCALE: 6" = 1'-0"

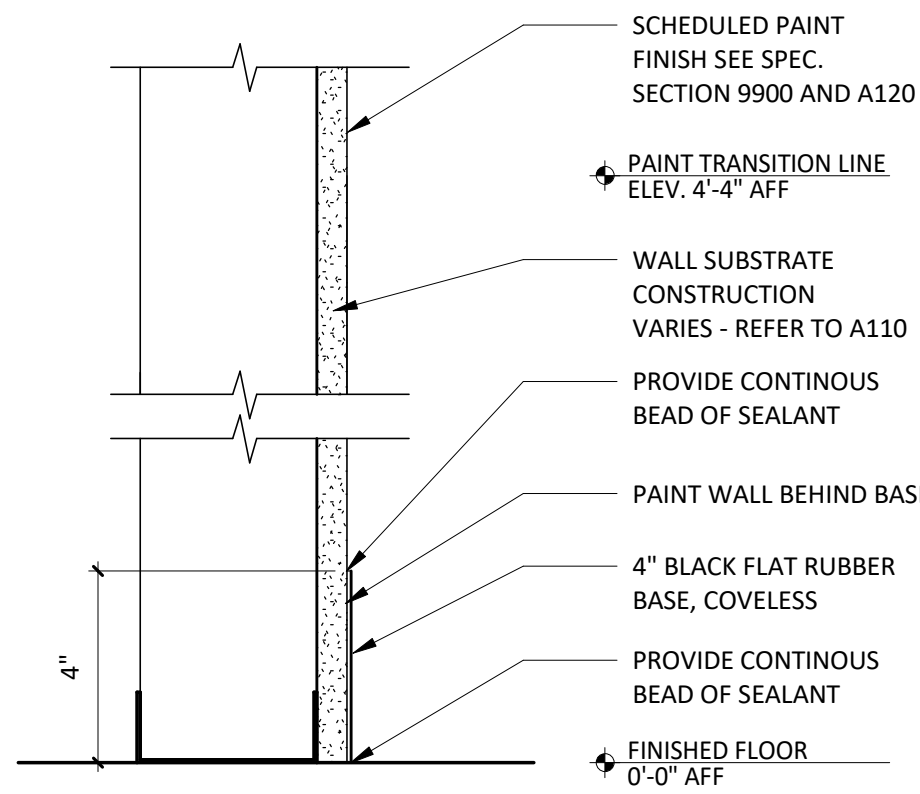



8 SECTION @ DINING ROOM WALL
SCALE: 3" = 1'-0"

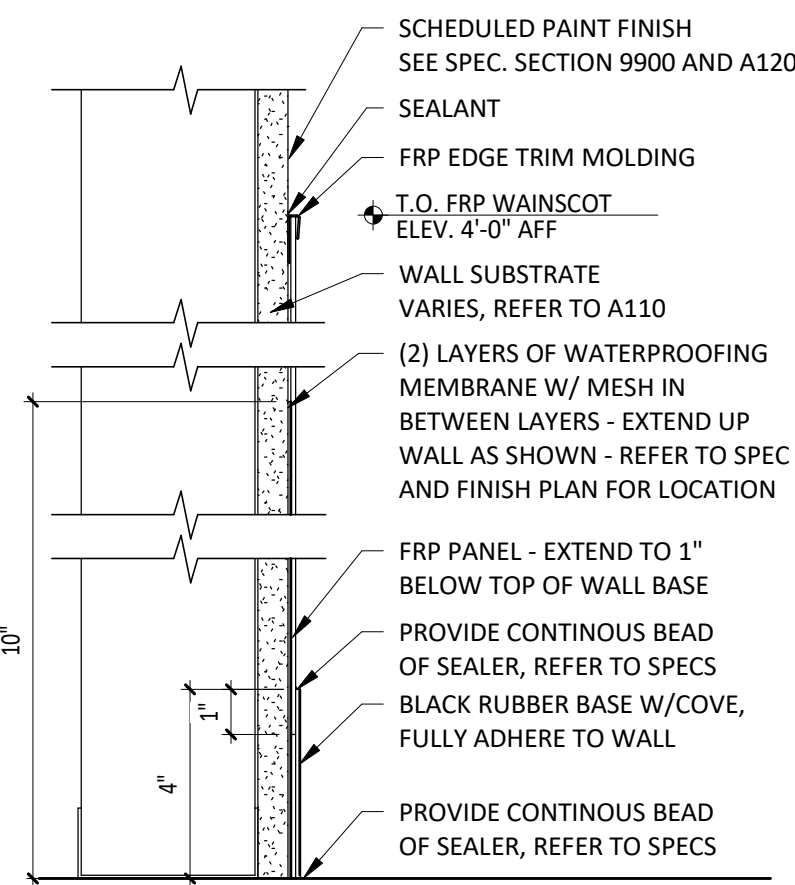


9 SECTION @ FRP WAINSCOT W/ RUBBER BASE
SCALE: 3" = 1'-0"

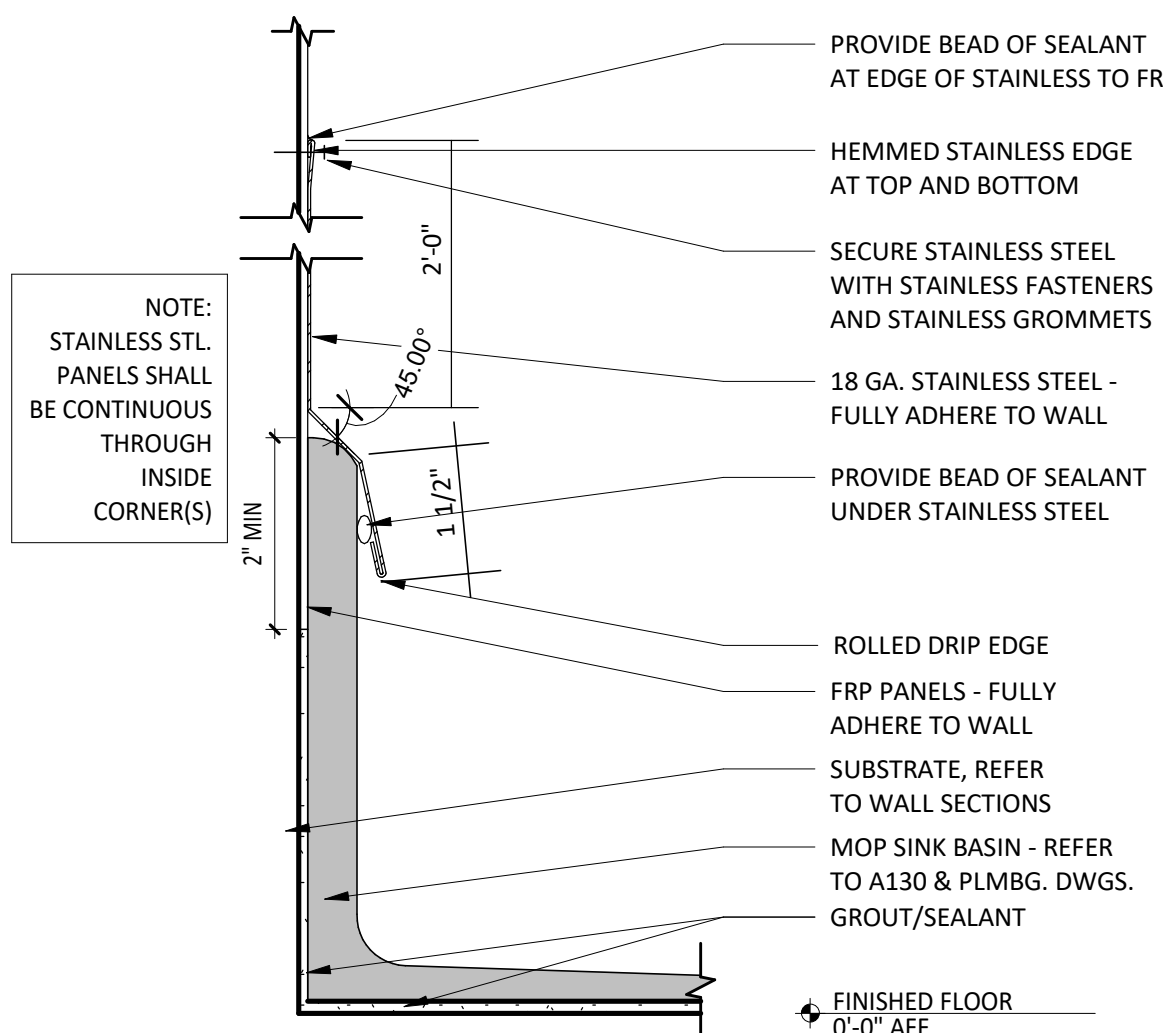

10 SECTION @ MOP SINK
SCALE: 6" = 1'-0"

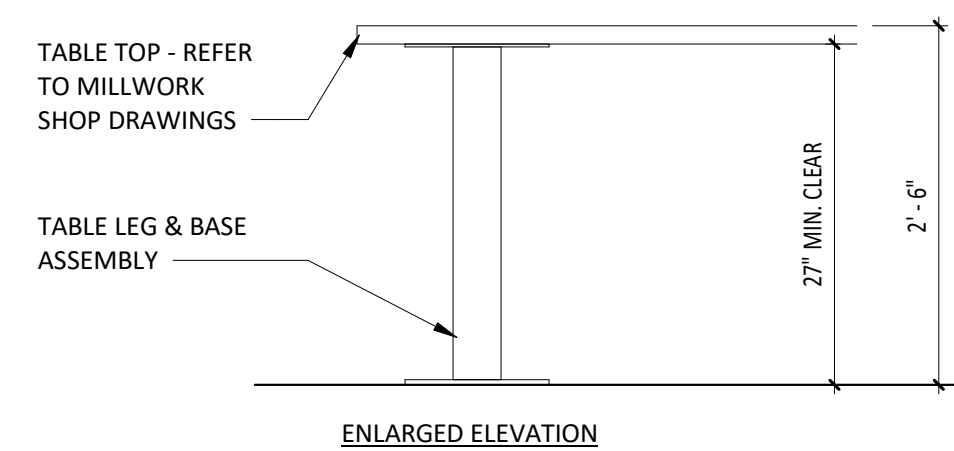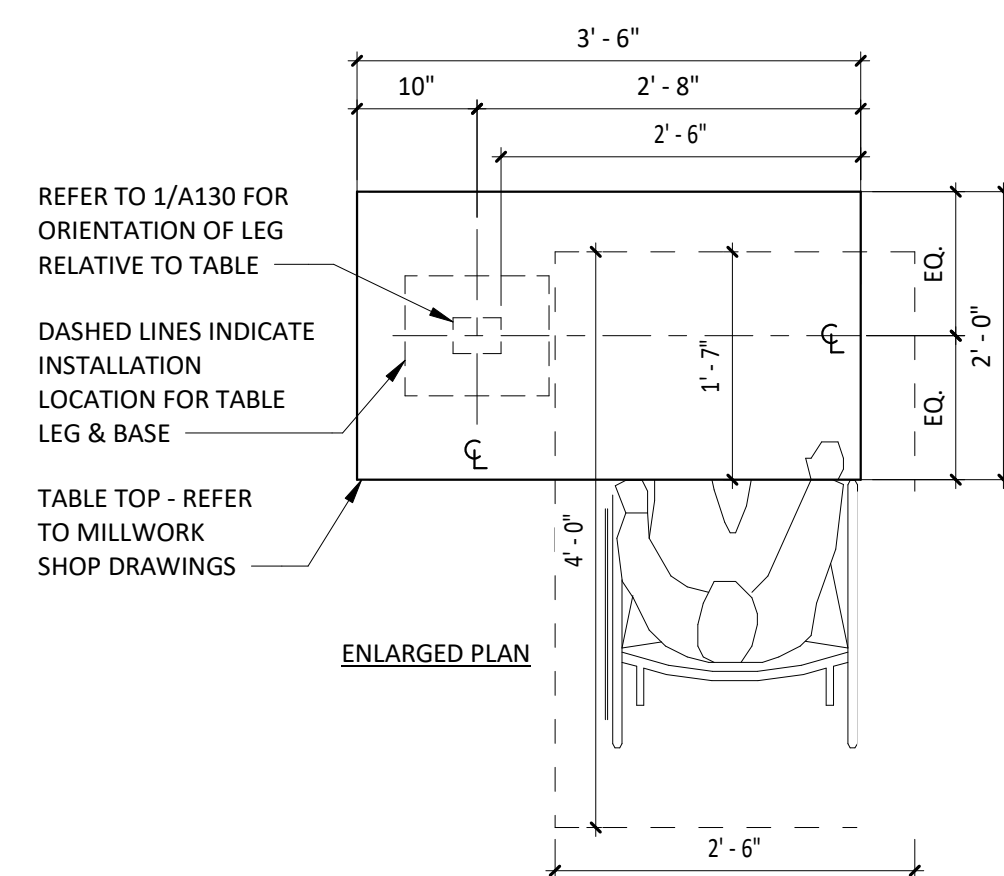

11 DETAIL @ ACCESSIBLE TABLE
SCALE: 3/4" = 1'-0"

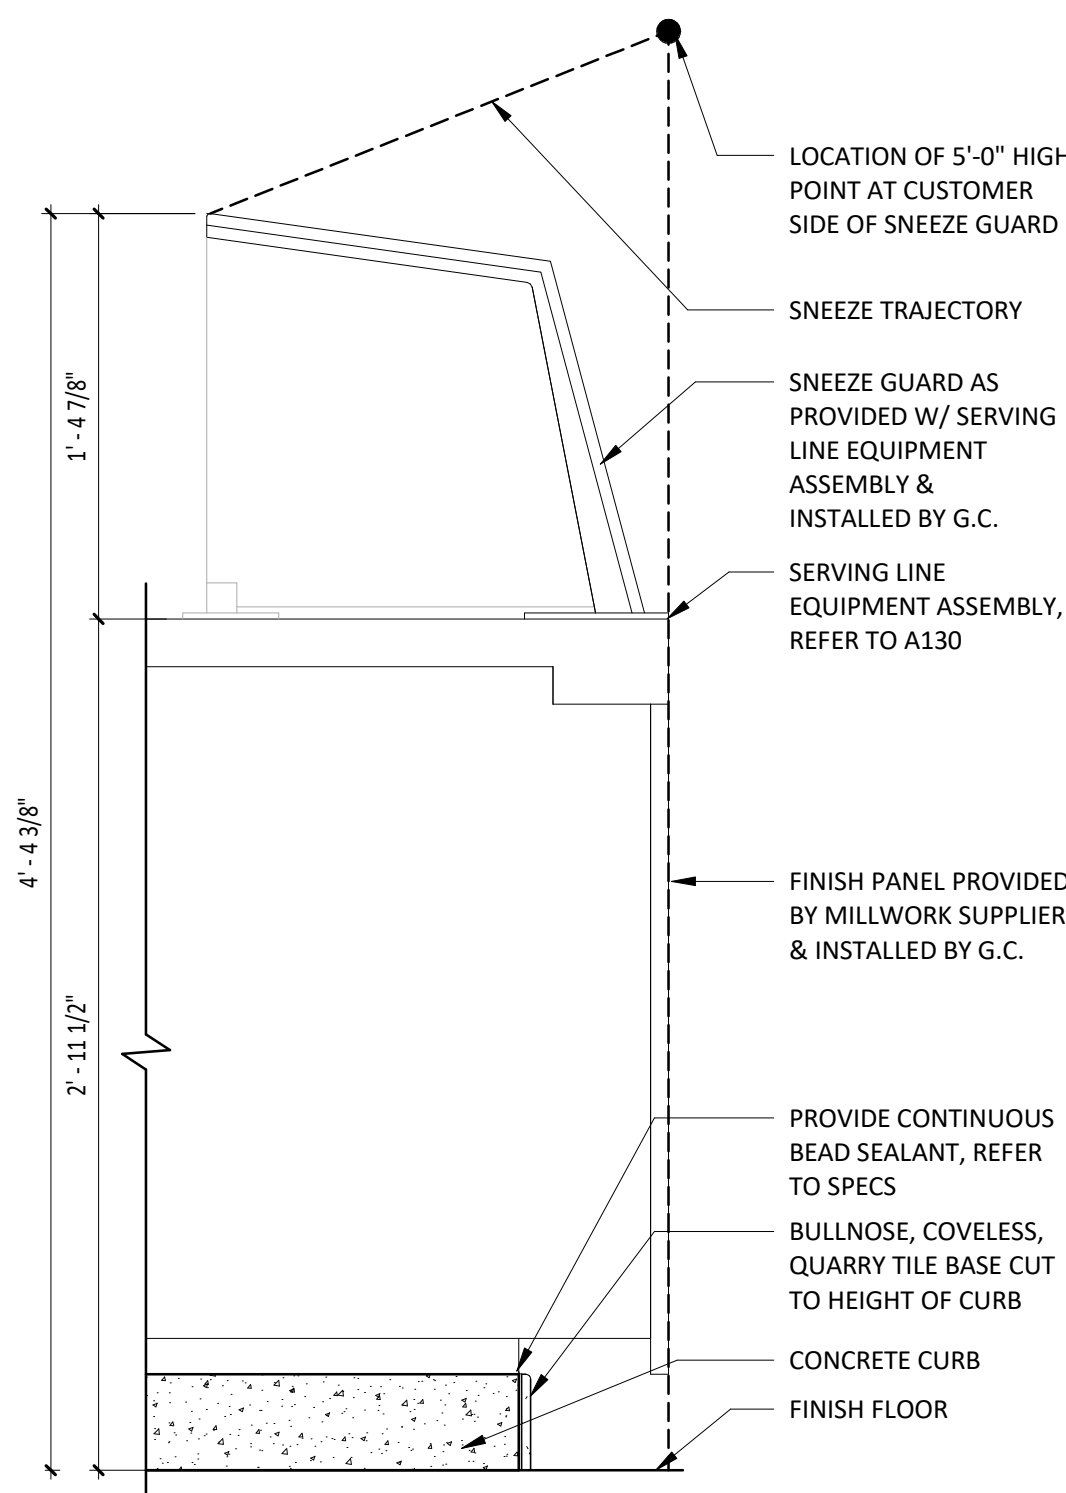

12 DETAIL @ SERVELINE SNEEZE GUARD
SCALE: 1 1/2" = 1'-0"



CLIENT:



CHIPOTLE MEXICAN GRILL, INC.
PO BOX 182966
COLUMBUS, OH 43218-2966
TELEPHONE: (614) 318-2682
INTERNET: WWW.CHIPOTLE.COM

COPYRIGHT 2024
THIS DRAWING IS AN INSTRUMENT OF SERVICE AND AS SUCH REMAINS THE PROPERTY OF CHIPOTLE MEXICAN GRILL, INC. PERMISSION FOR USE OF THIS DOCUMENT IS LIMITED AND CAN BE EXTENDED ONLY BY WRITTEN AGREEMENT WITH CHIPOTLE MEXICAN GRILL, INC.

PROJECT INFORMATION:

STORE NO.: 4757
"ANDERSON IN"
S SCATTERFIELD RD & 59TH STREET
ANDERSON, IN 46013

SEAL:



July 25, 2024
MATTHEW M. WILKUS
LICENSE #A11700110
(EXPIRES 12/31/2024)























PROJECT NO. 2022-0494
DRAWN BY RDB
CHECKED BY

ISSUE RECORD:
12/12/2023 PERMIT SET
06/19/2024 BID SET
07/24/2024 CONSTRUCTION SET

REVISIONS:
1 05/20/2024 DB UPDATES

TITLE:
FINISH DETAILS - GENERAL

SHEET NUMBER:
A801

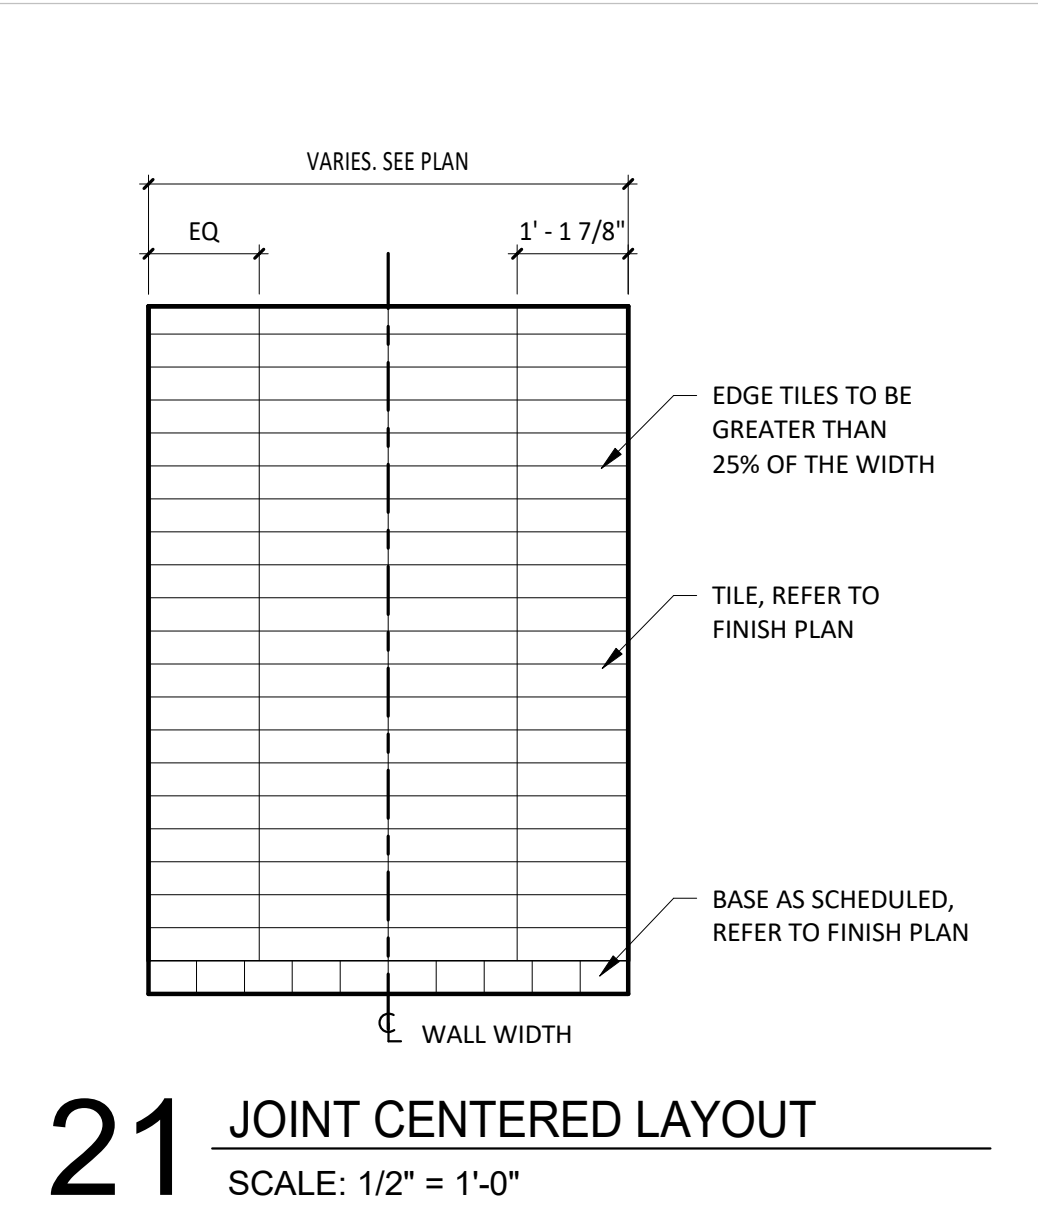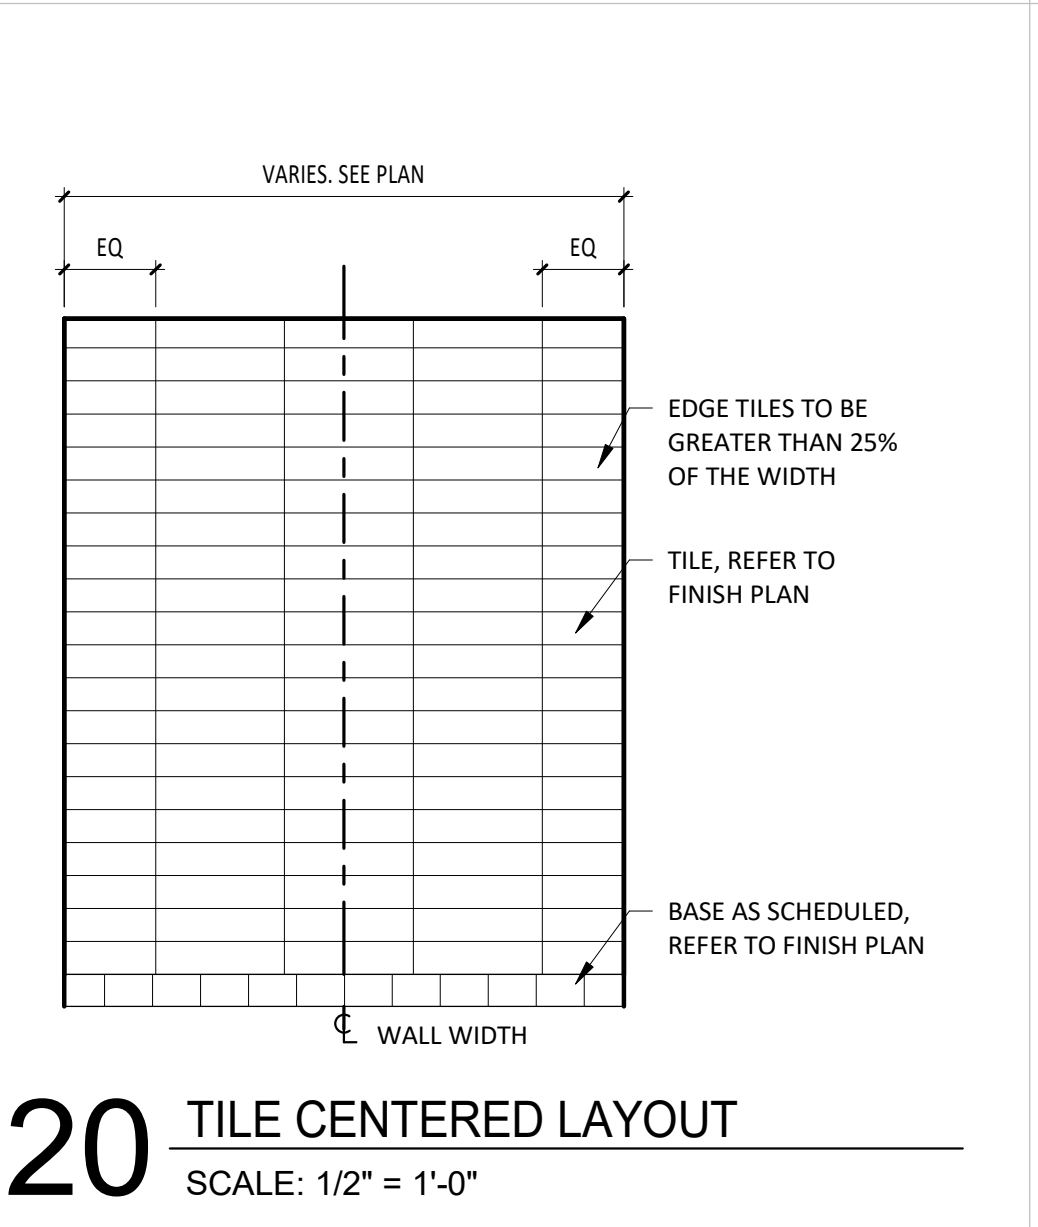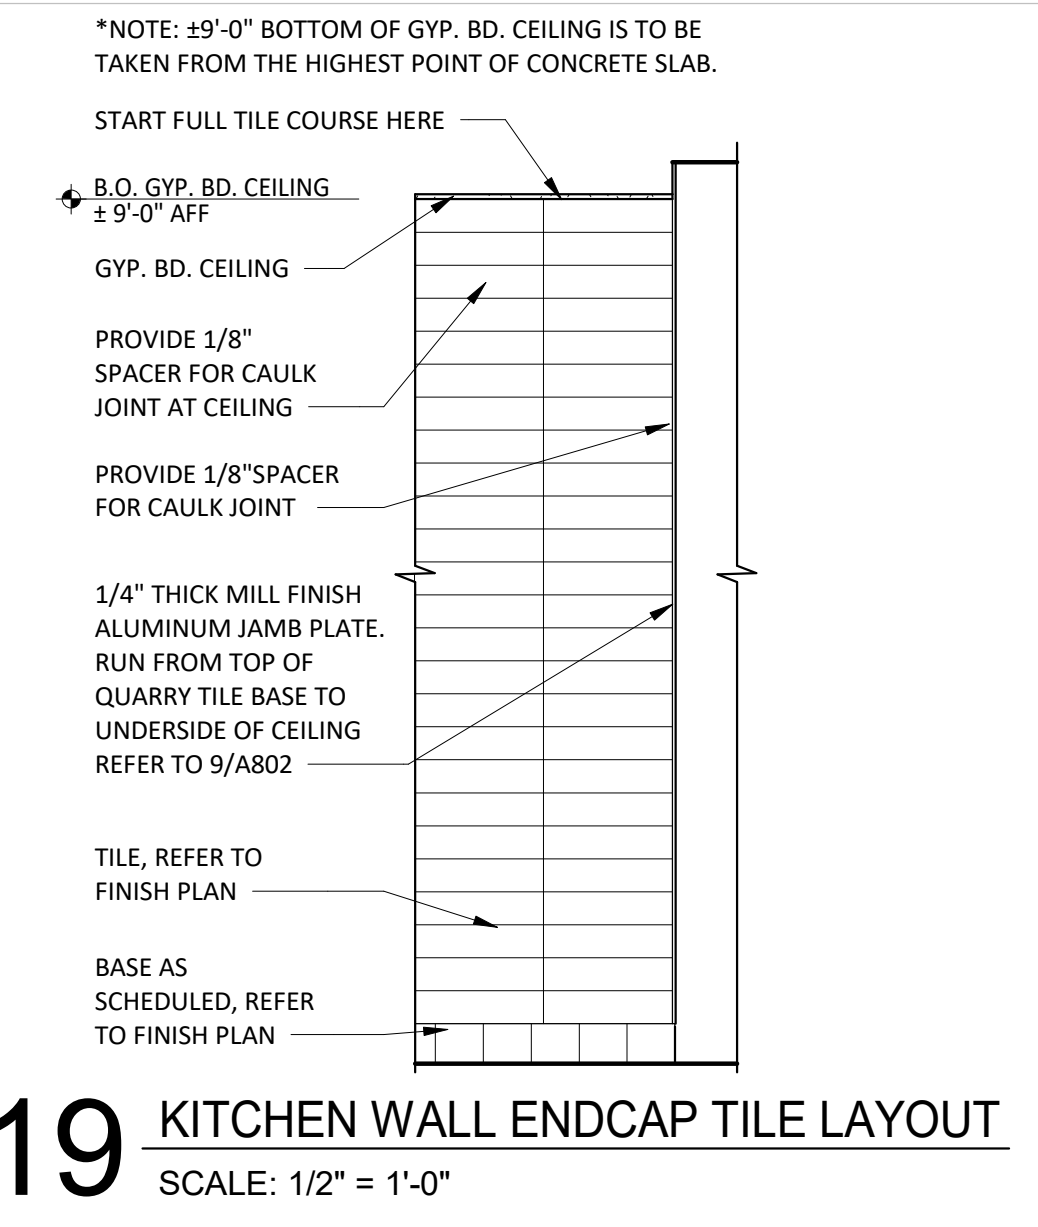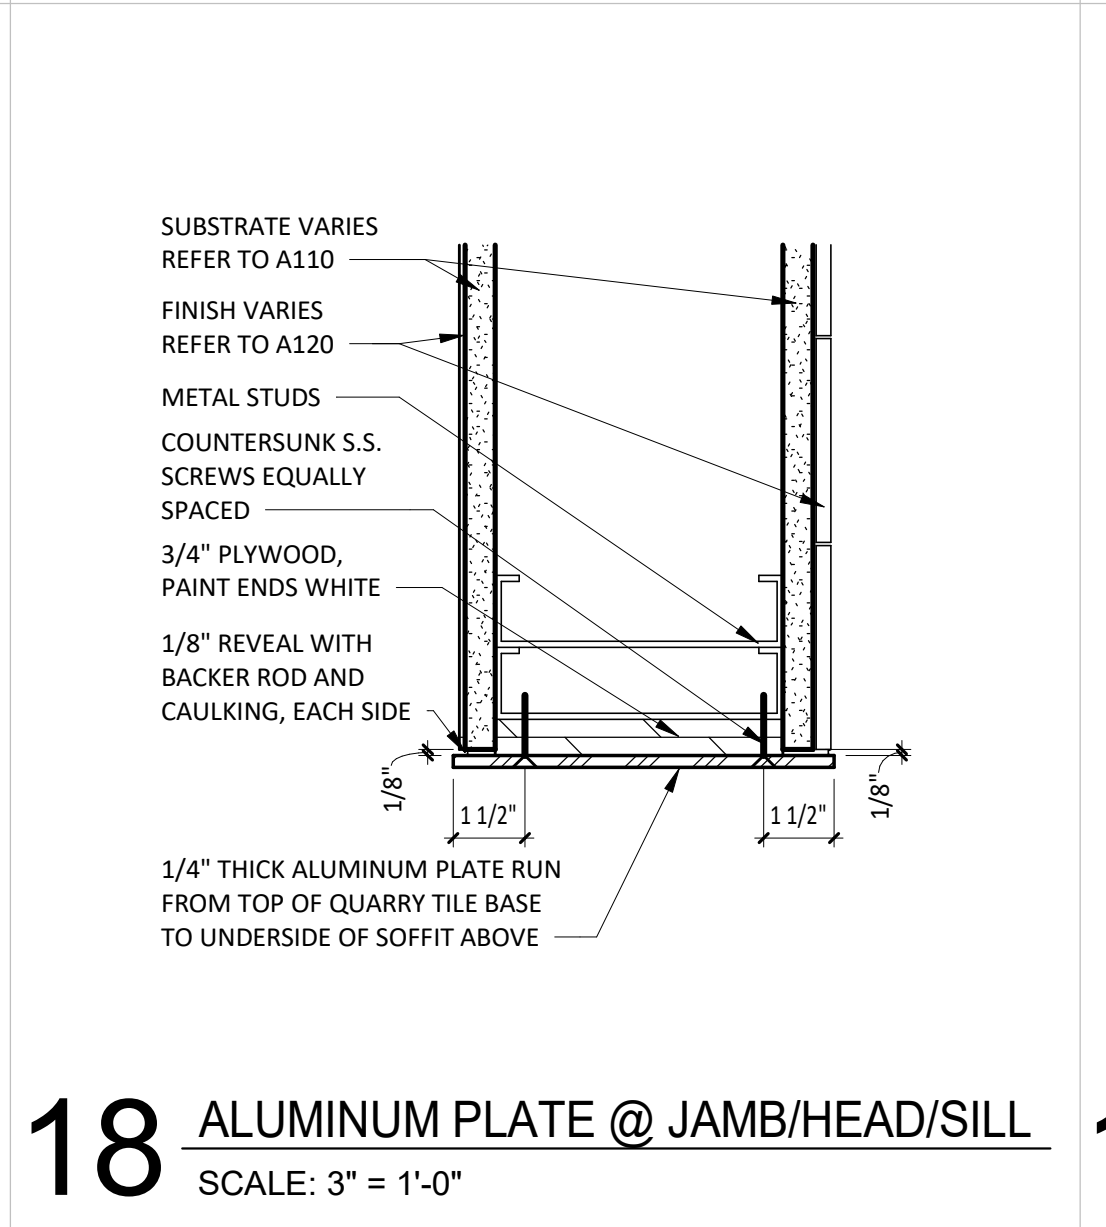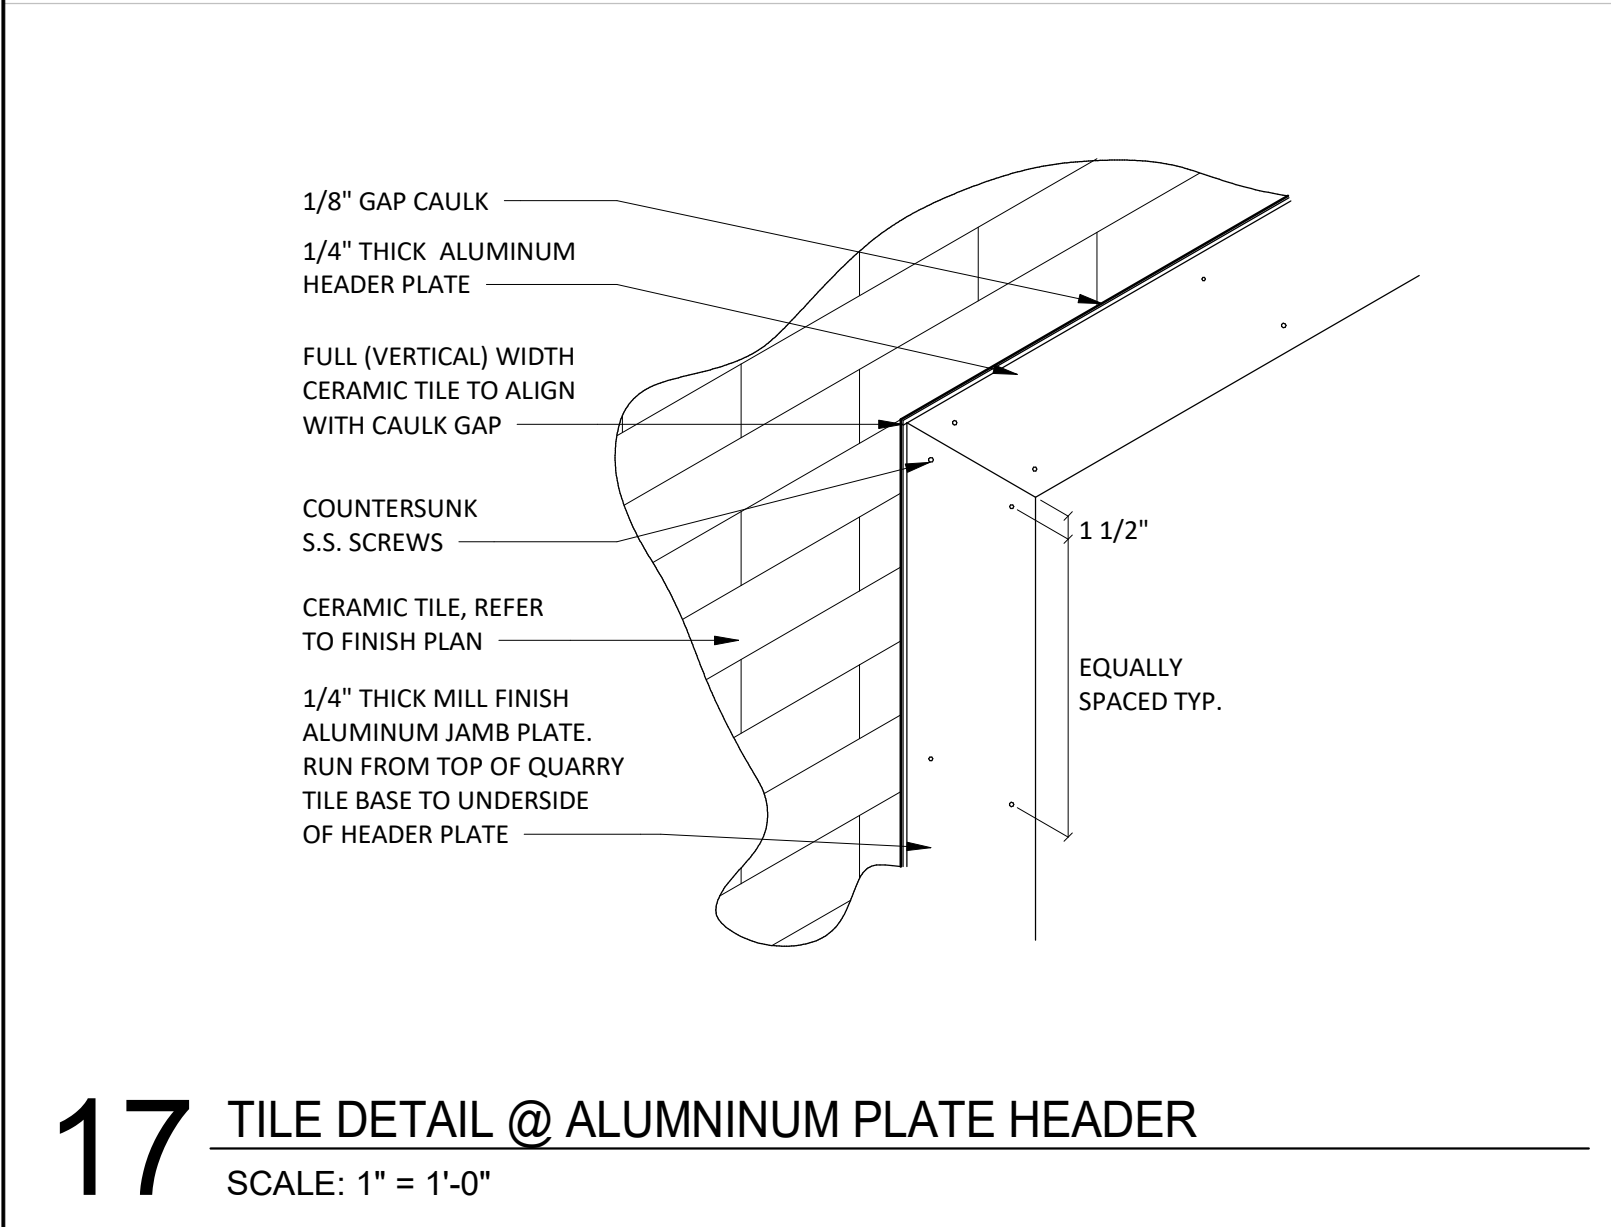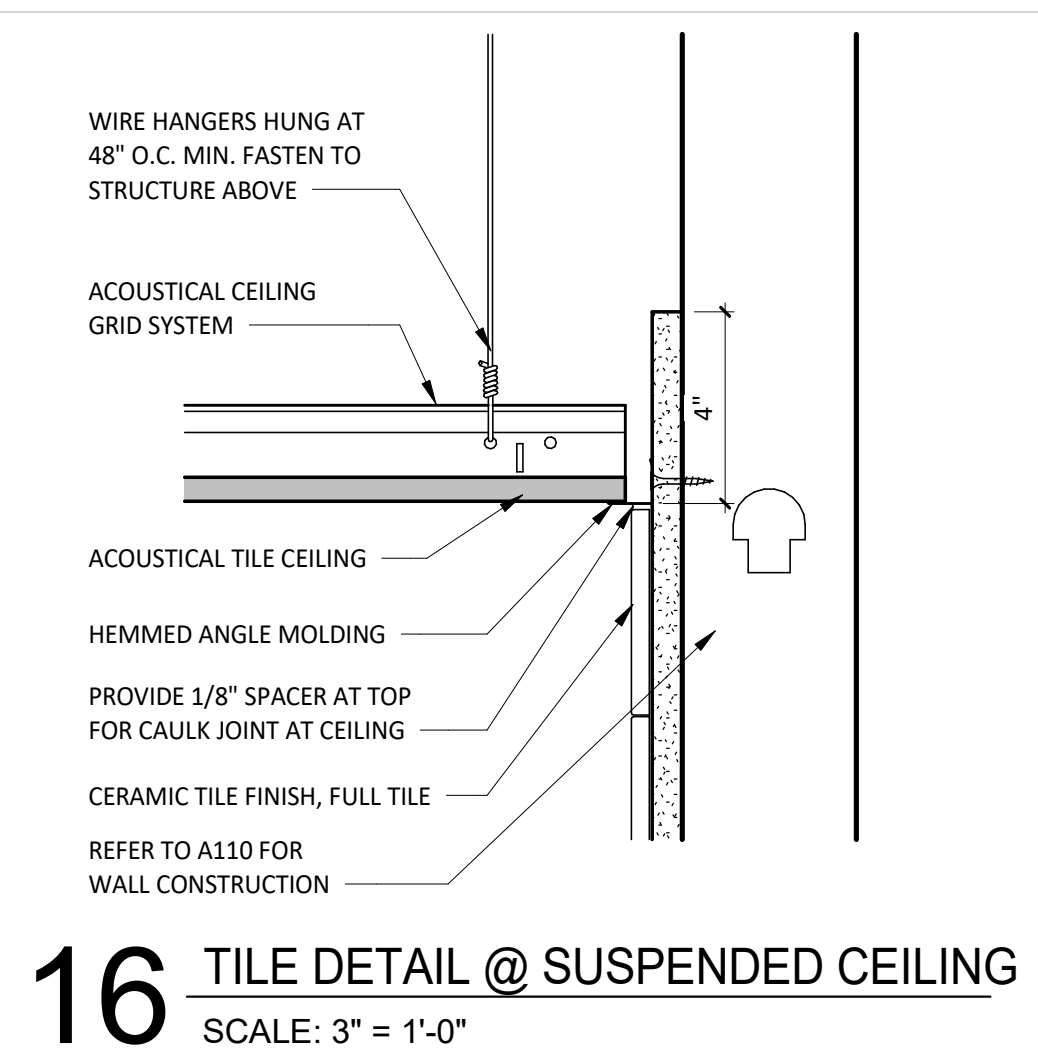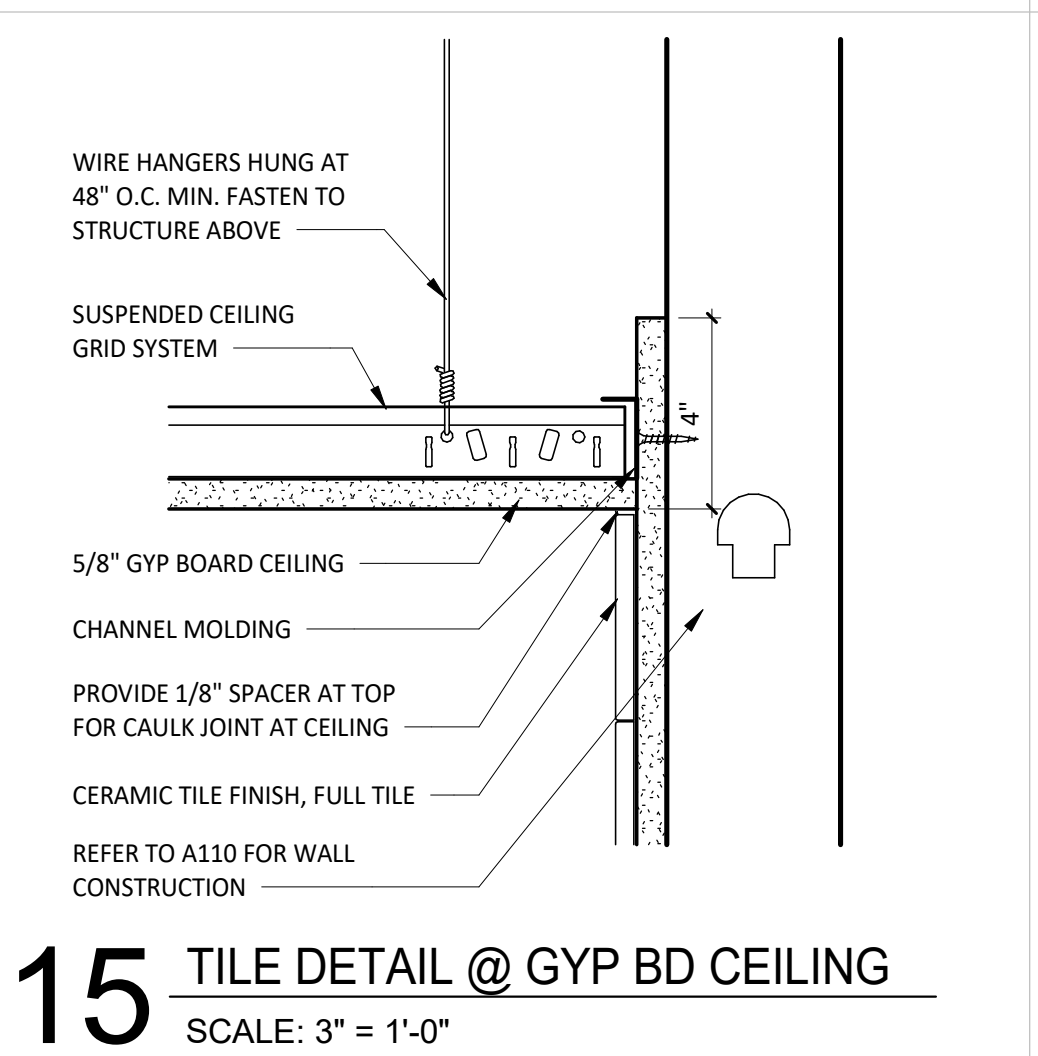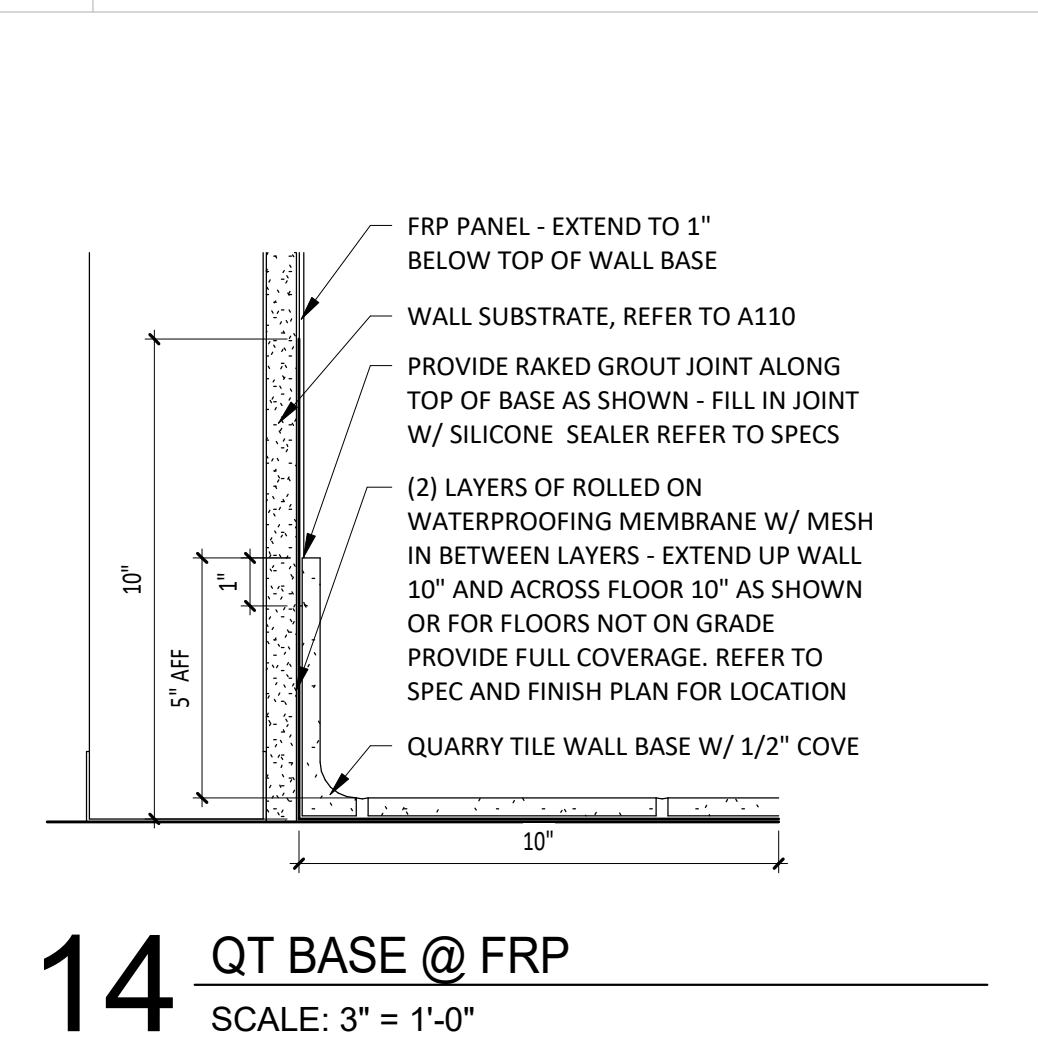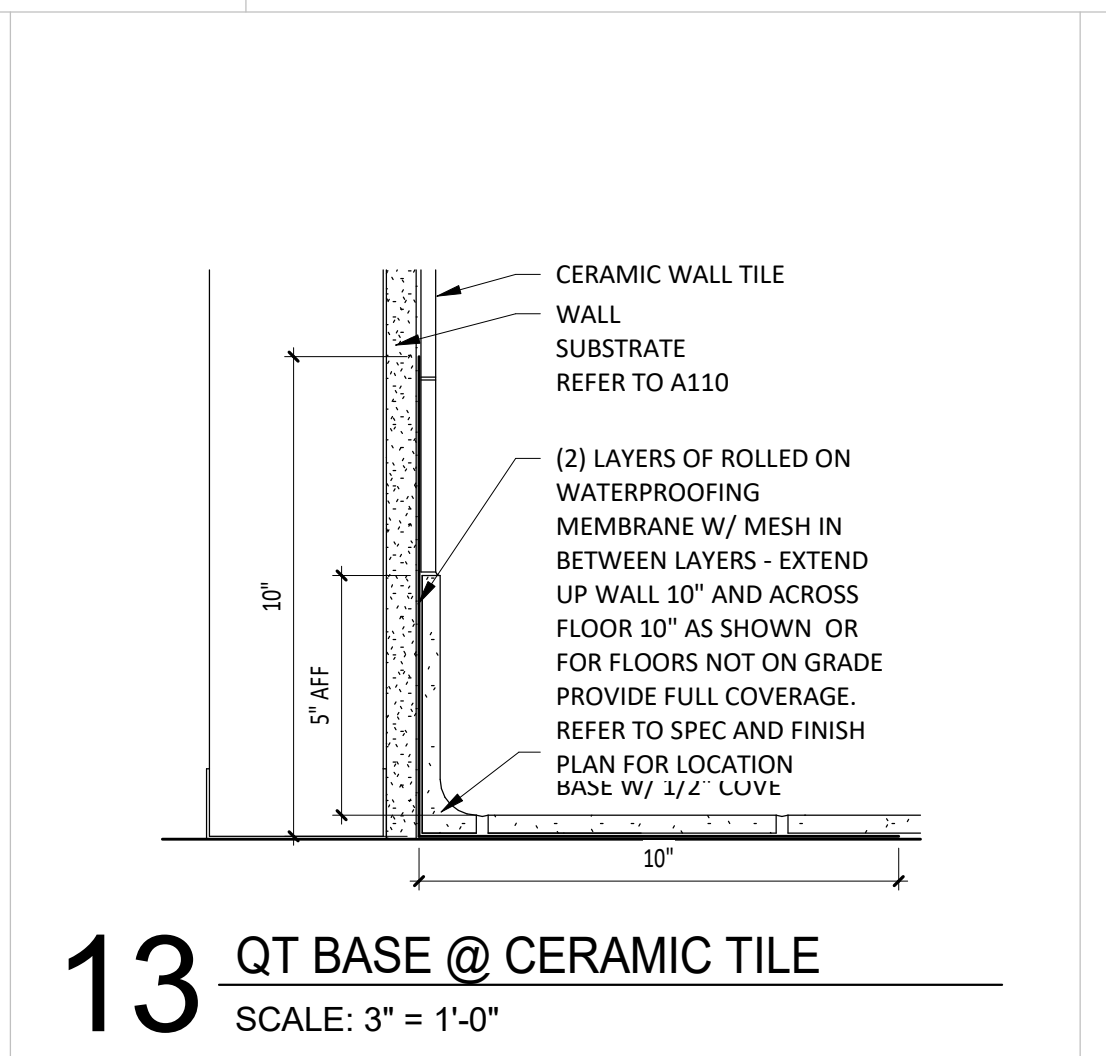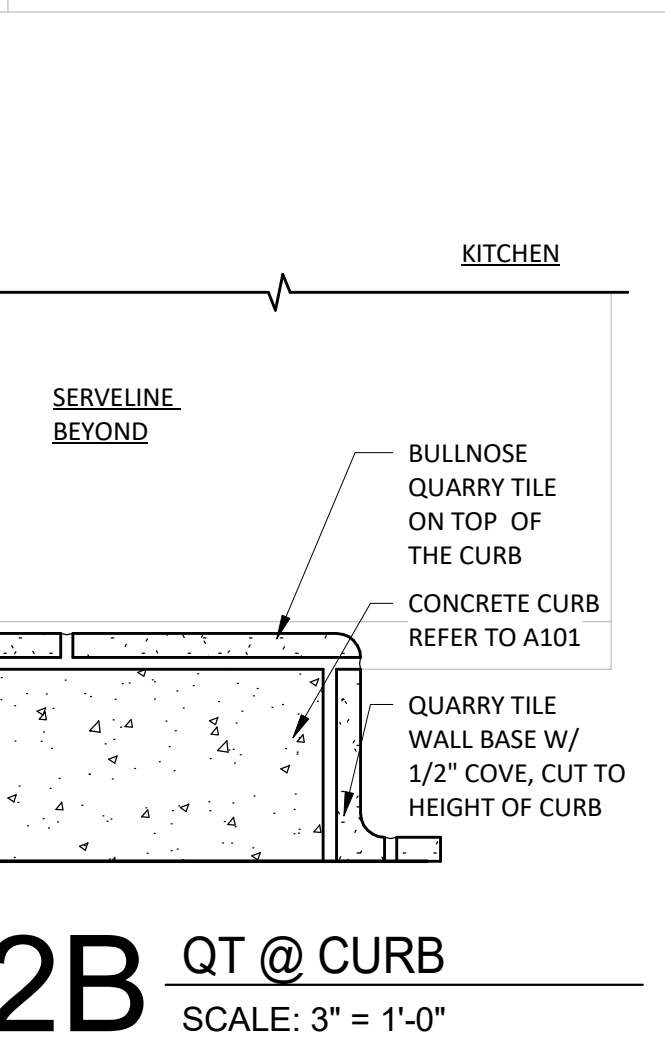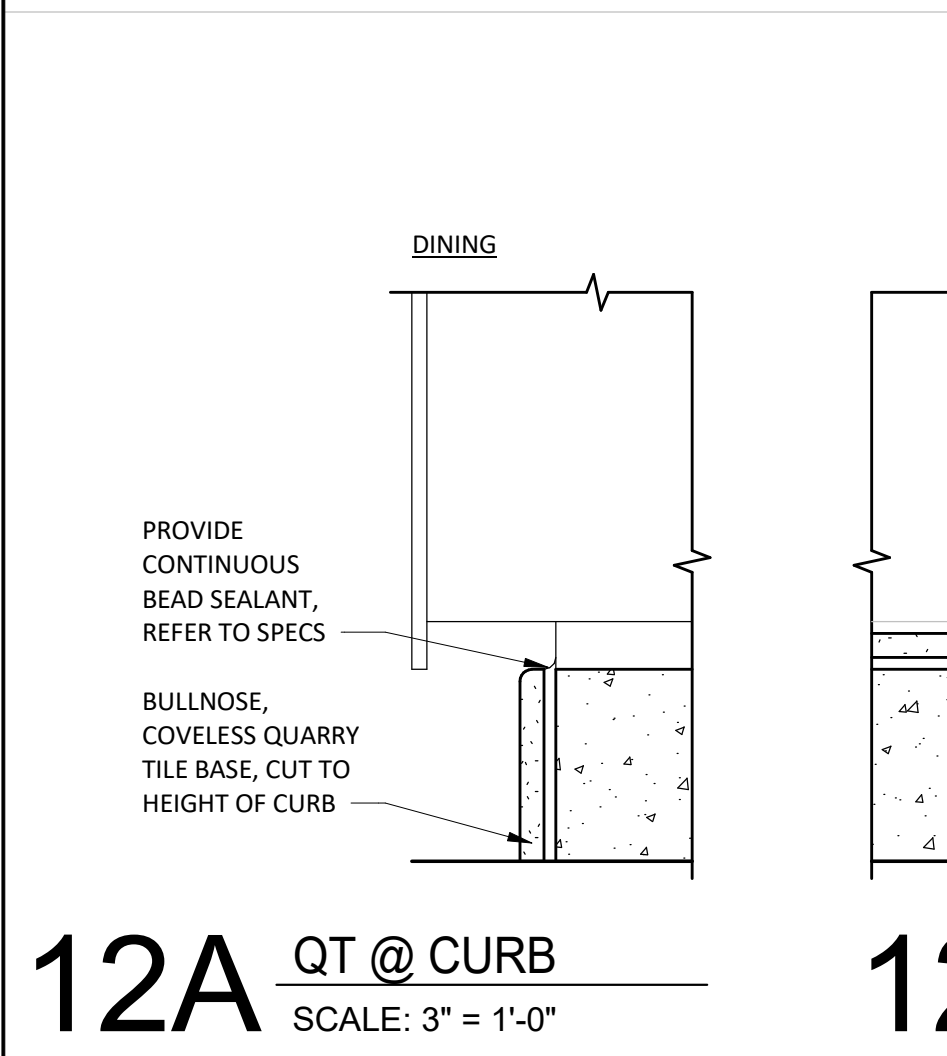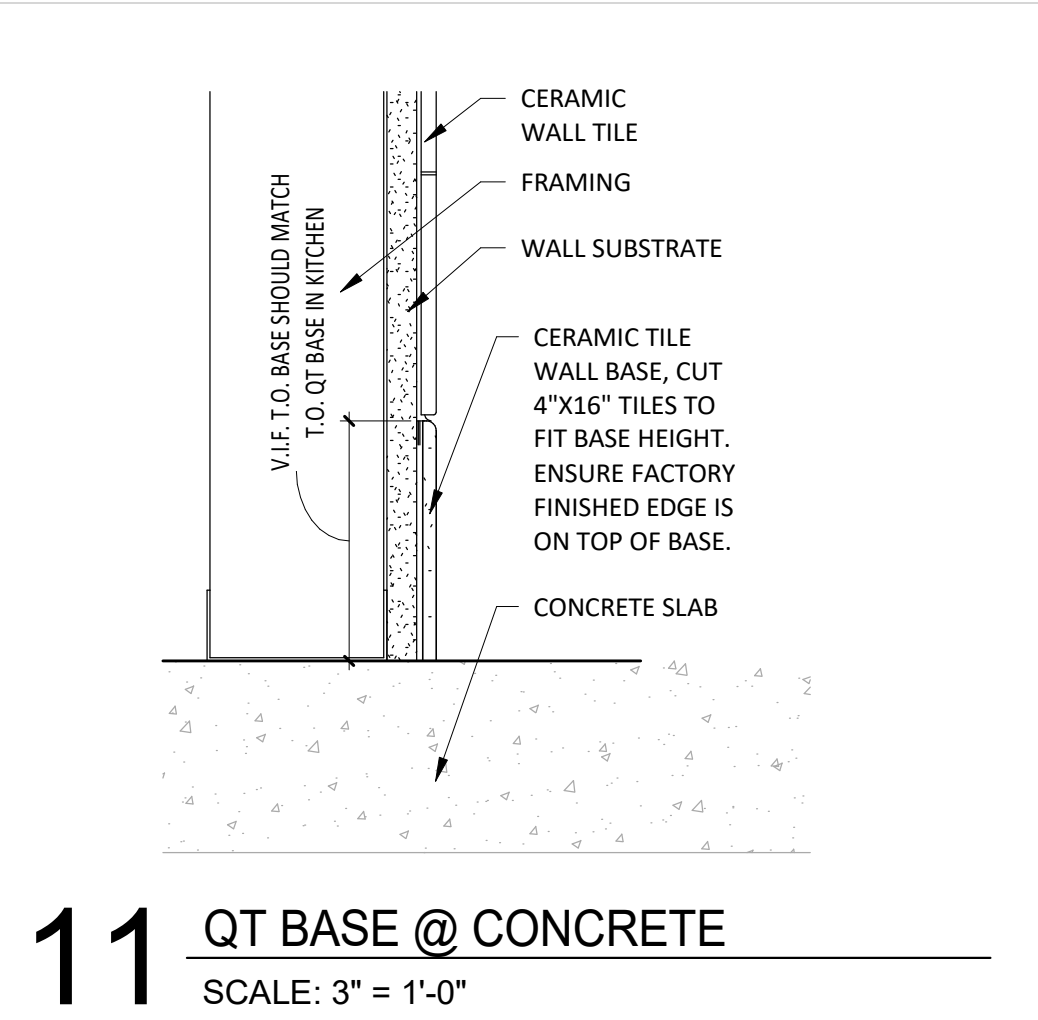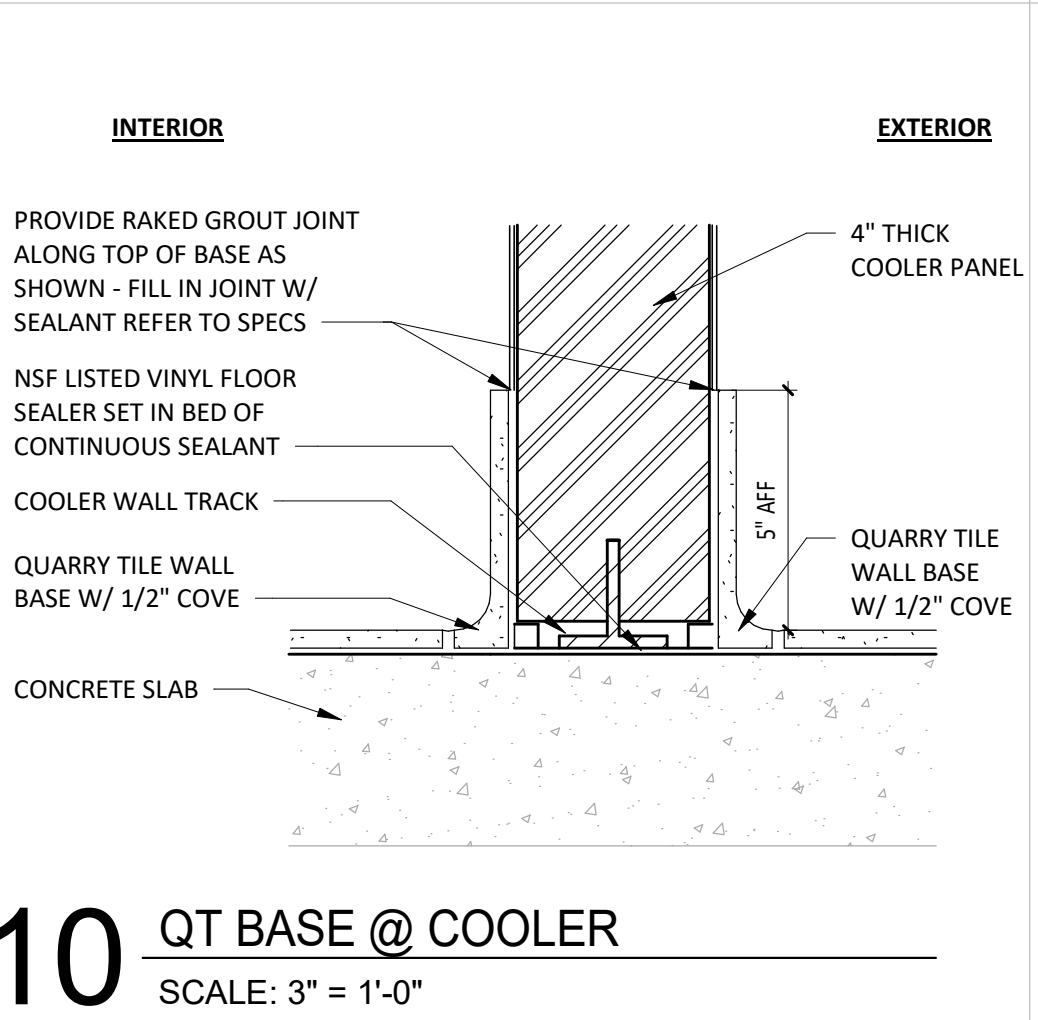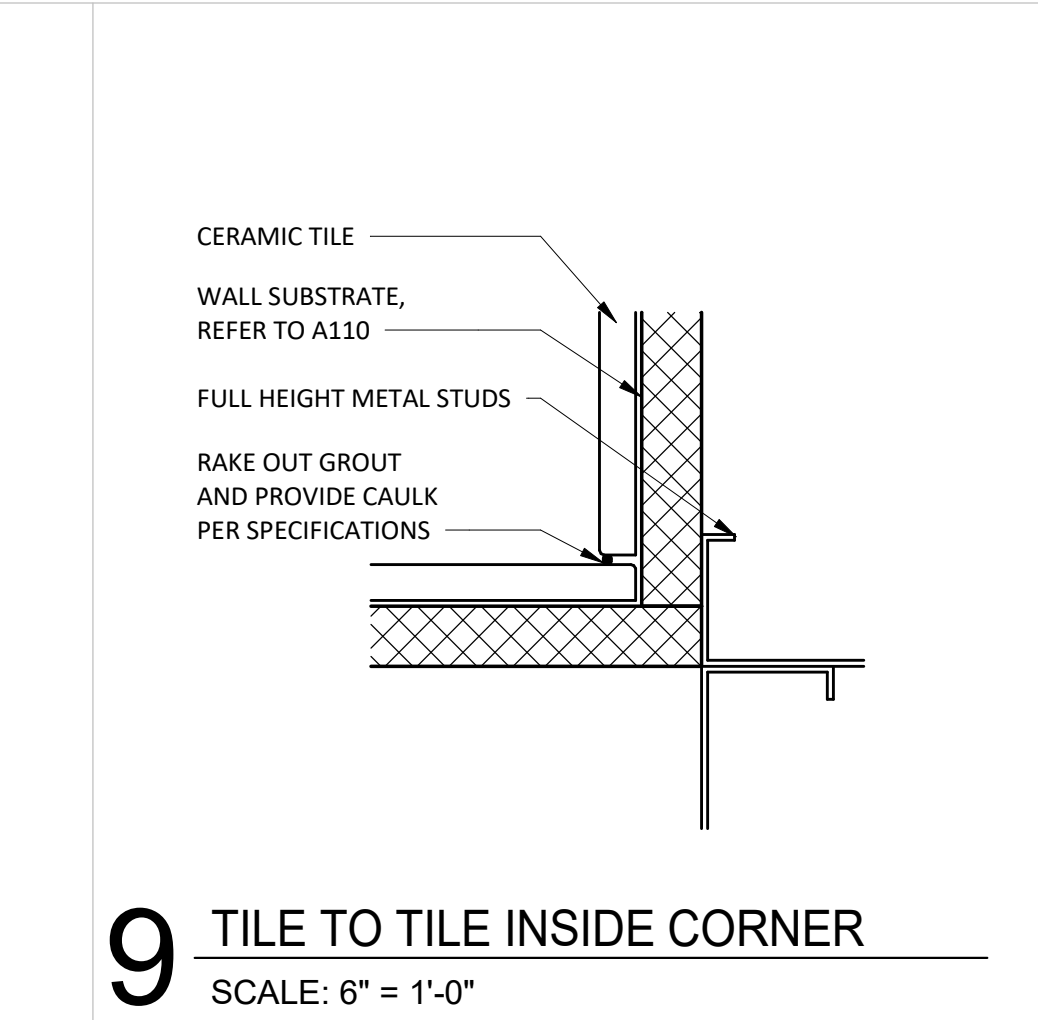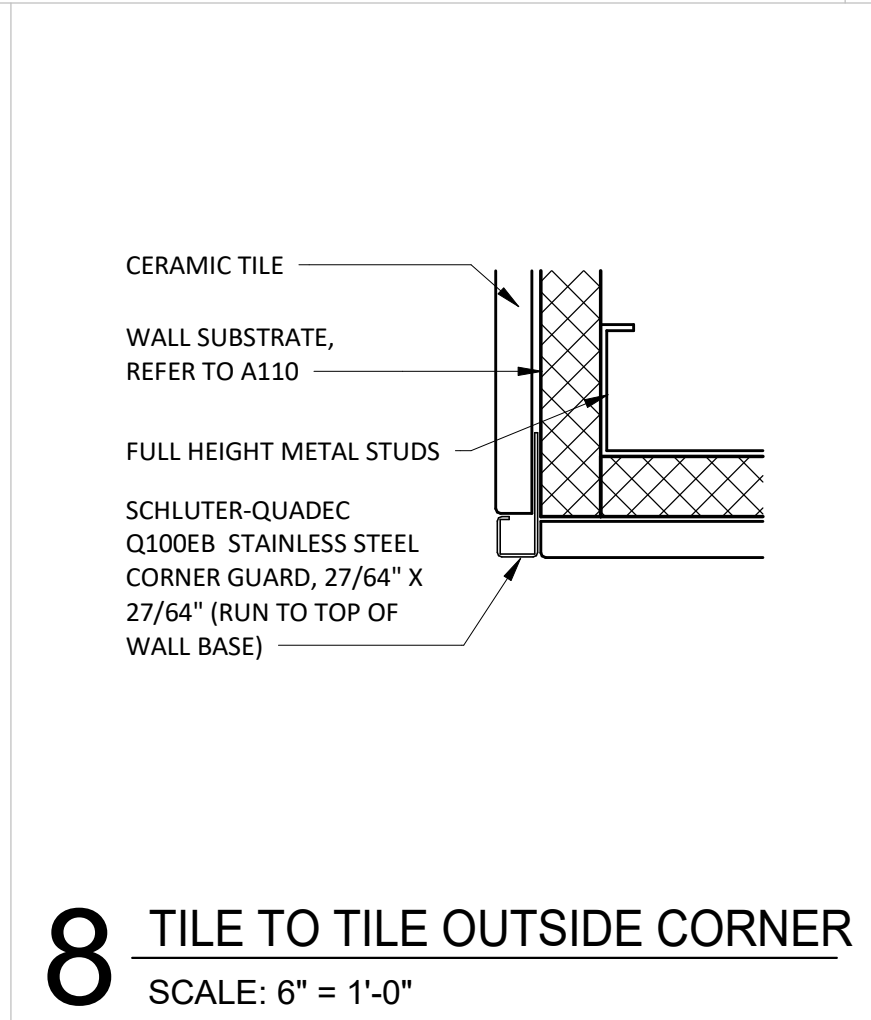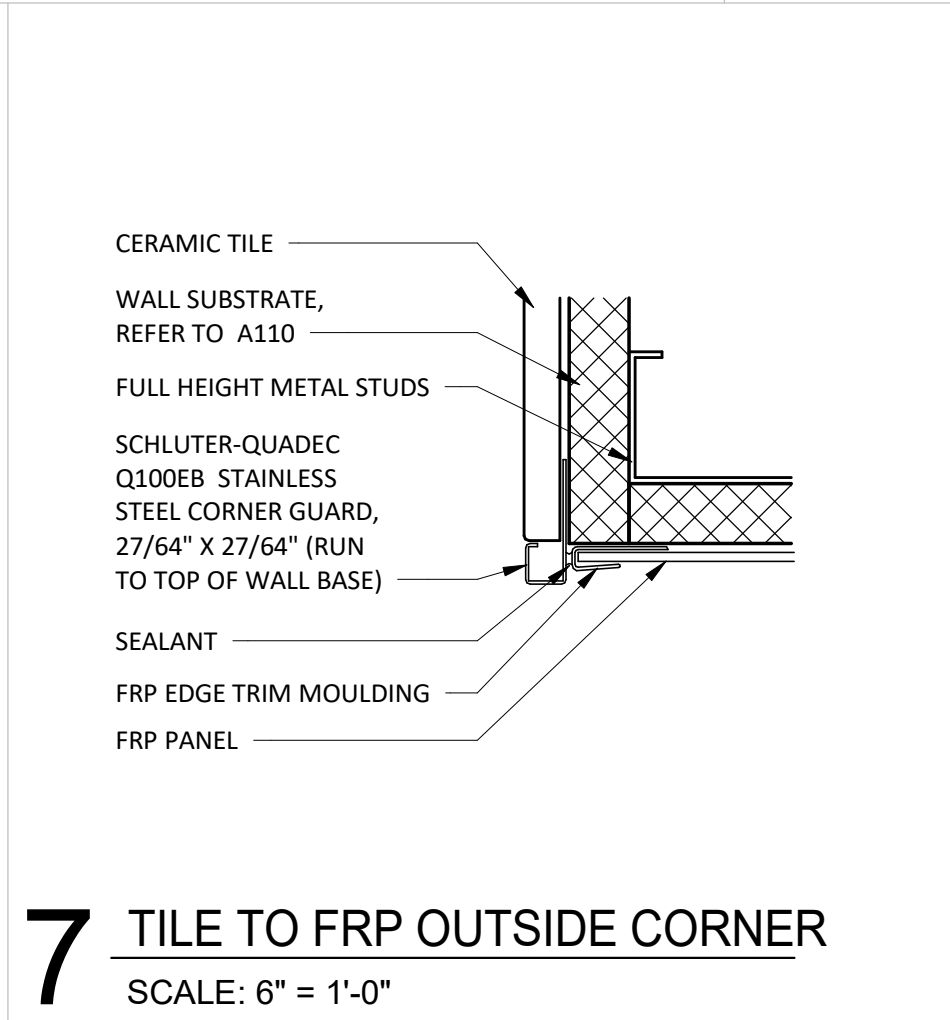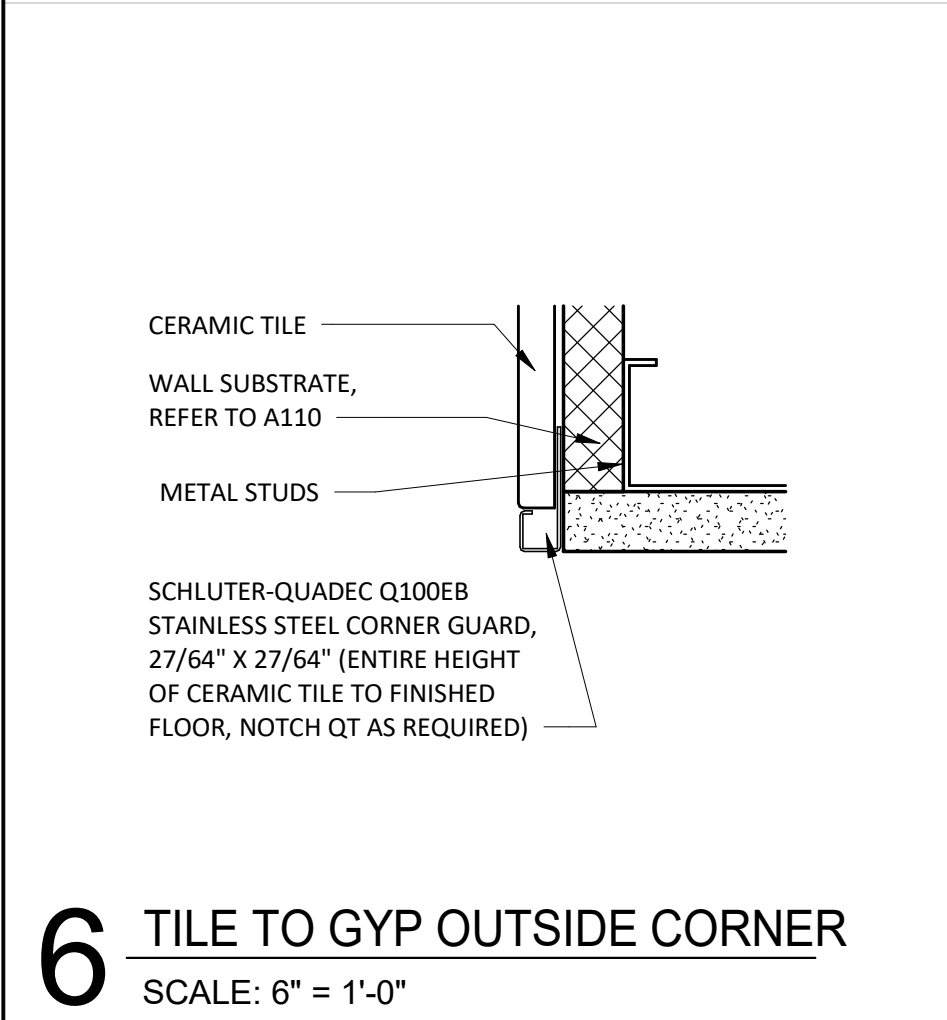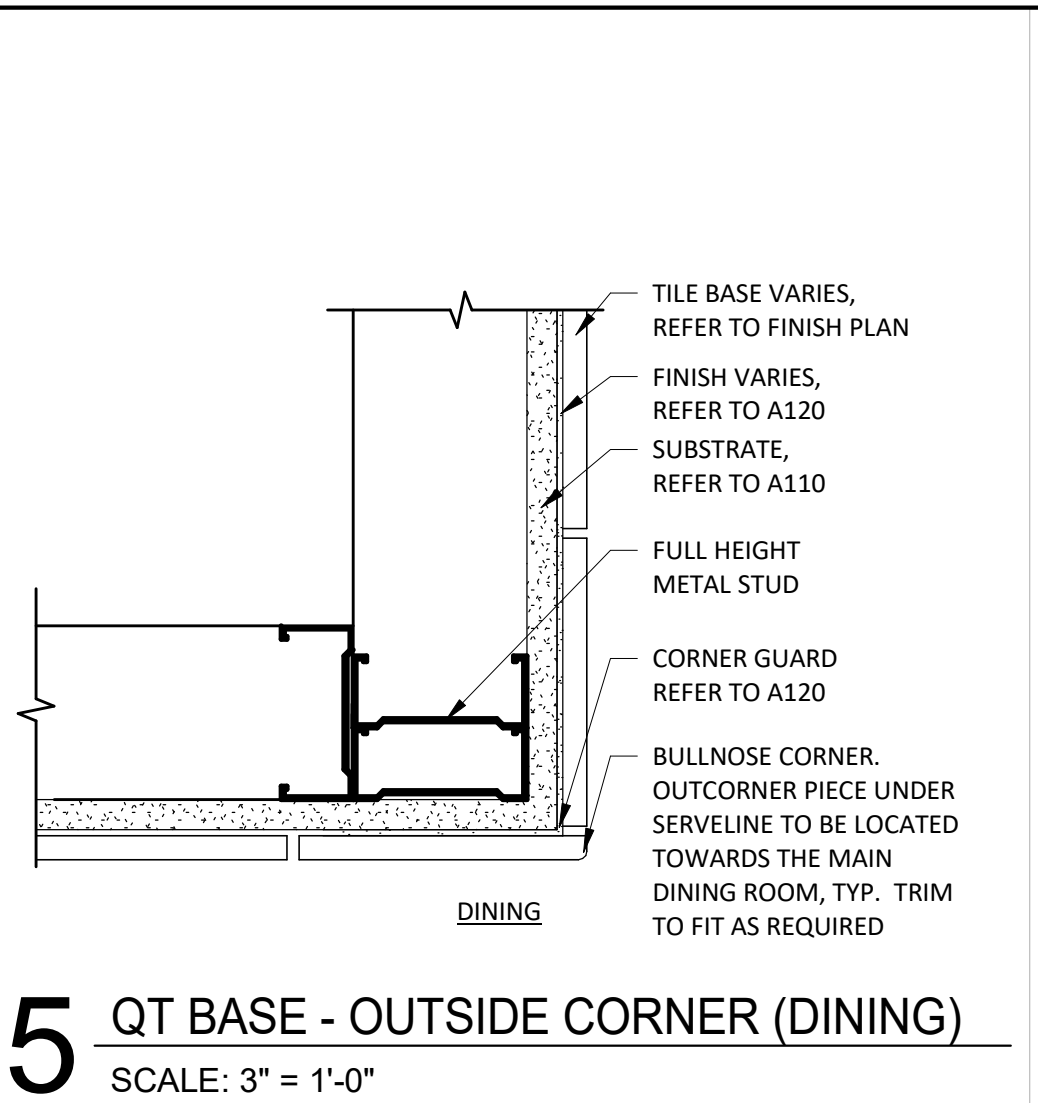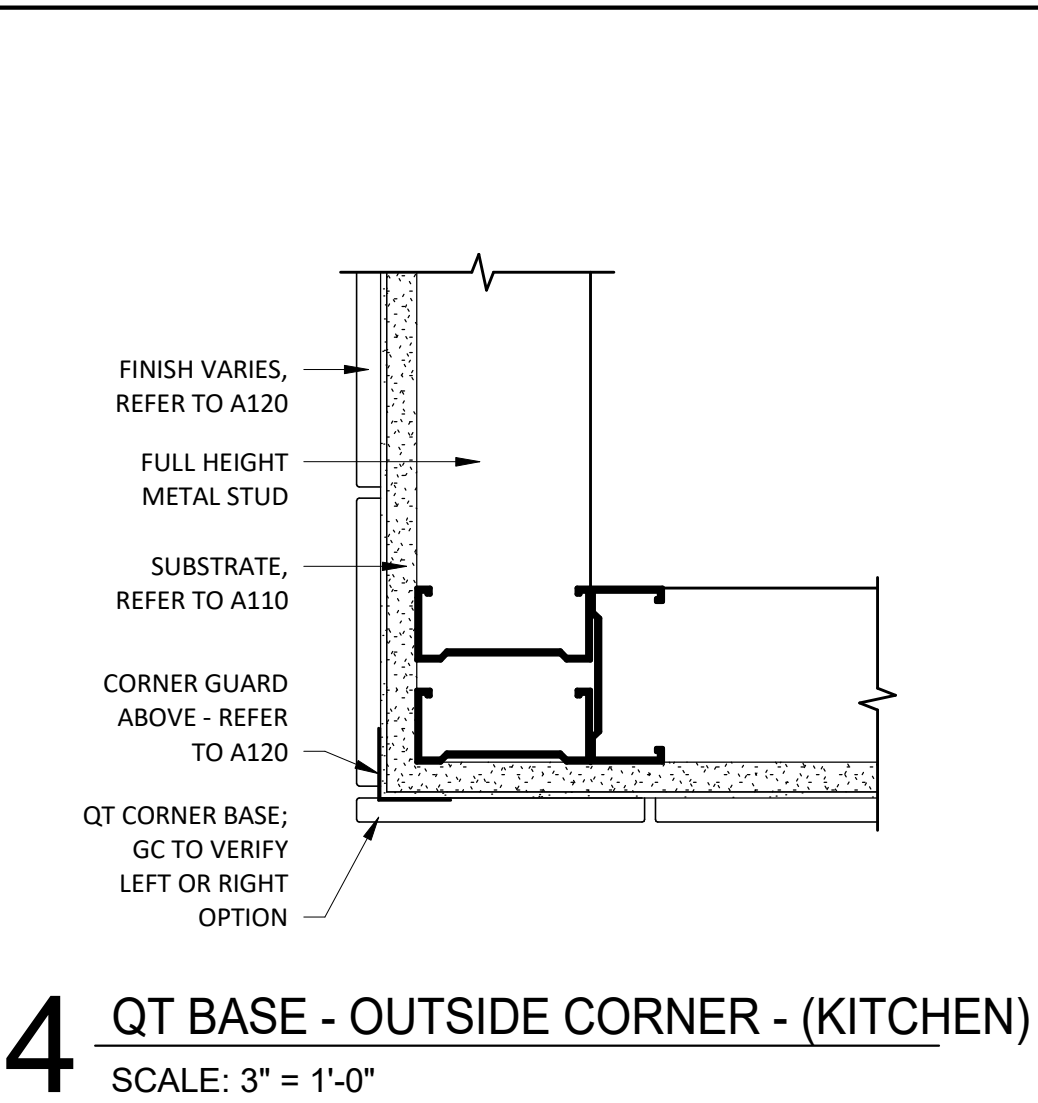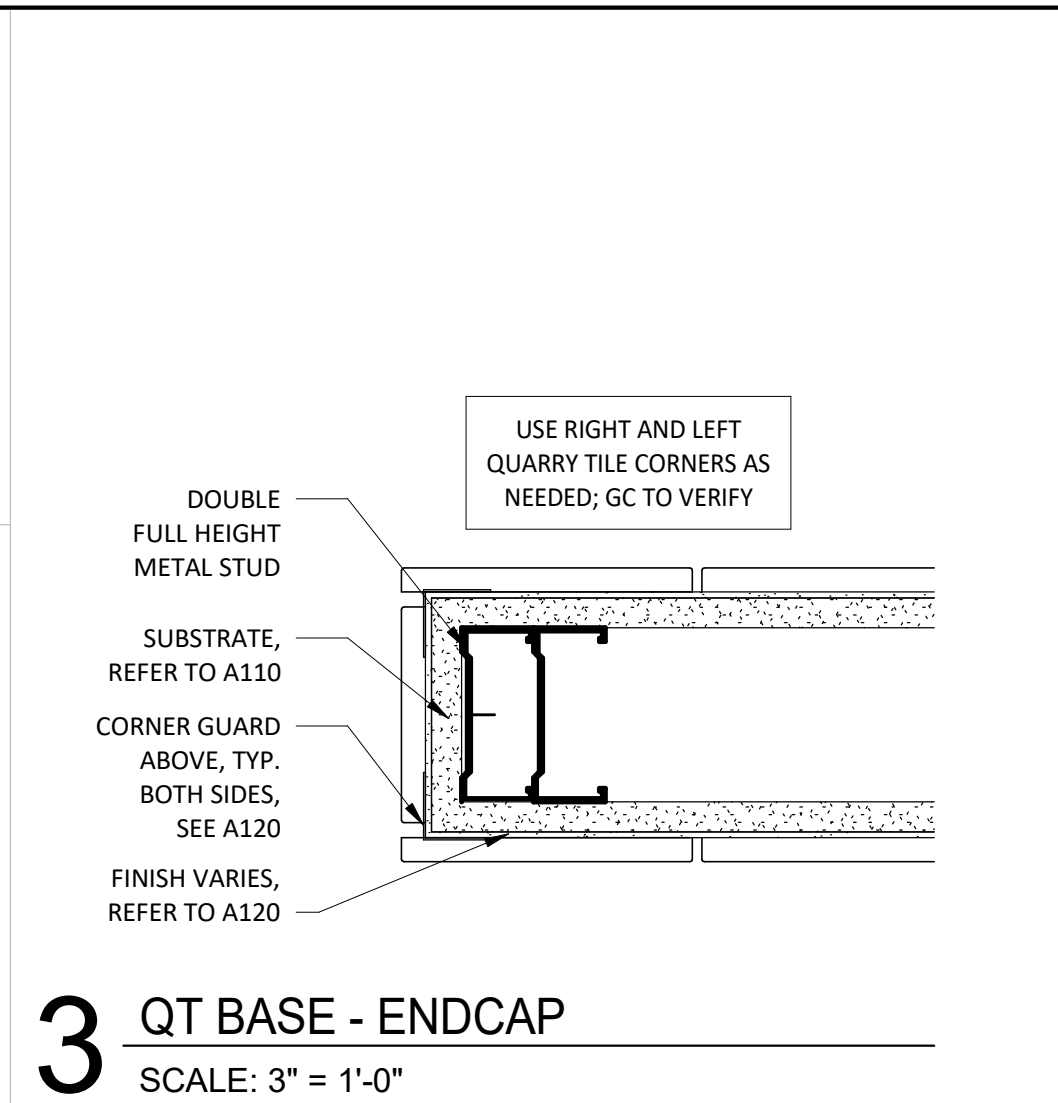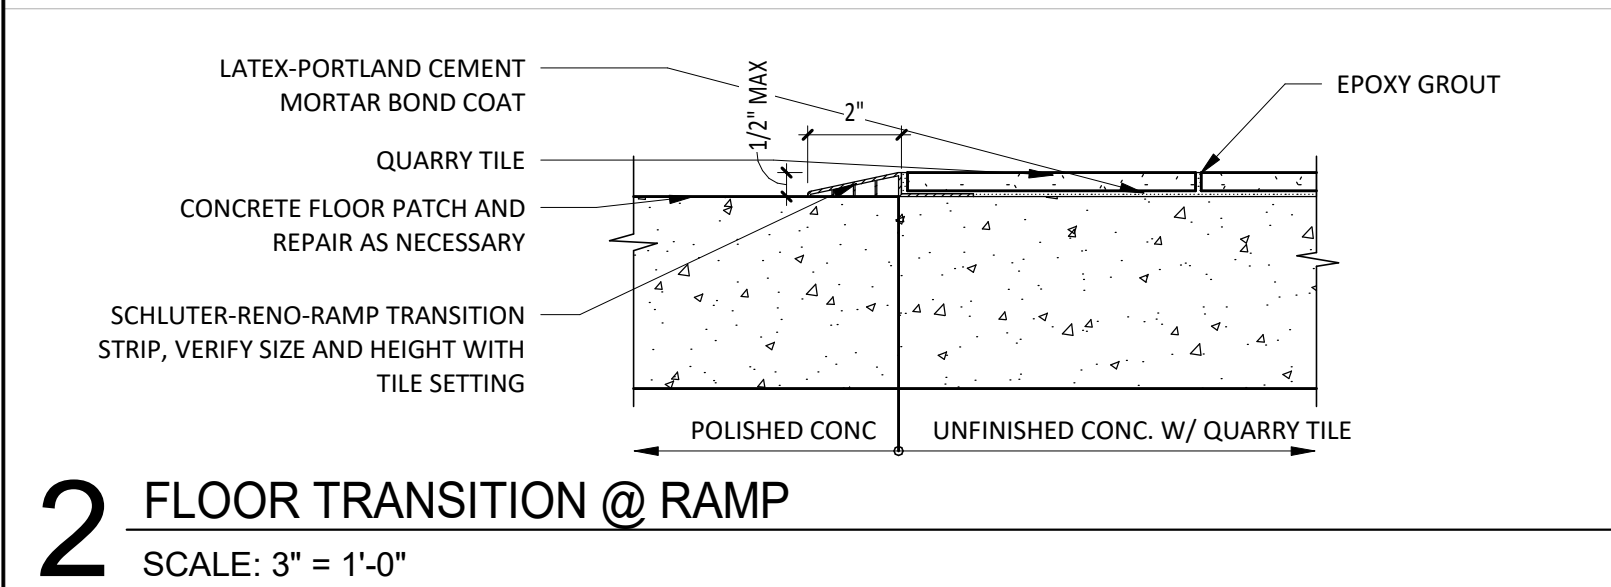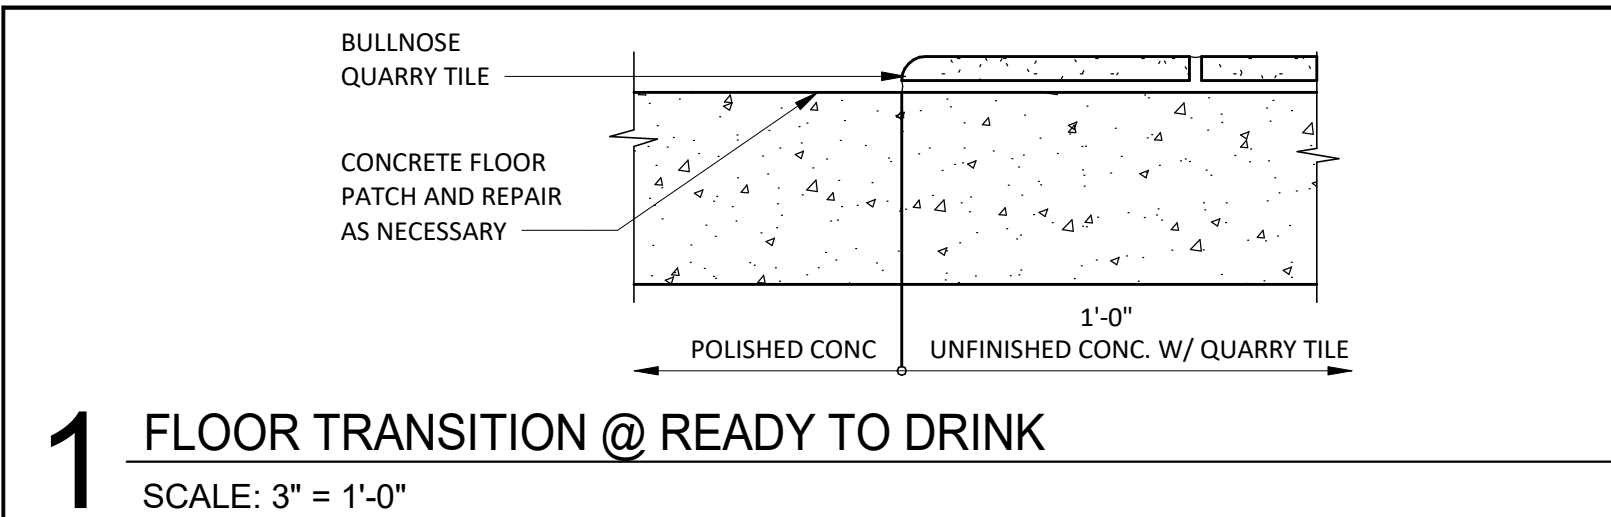

CLIENT:

CHIPOTLE MEXICAN GRILL, INC.
PO BOX 182966
COLUMBUS, OH 43218-2966
TELEPHONE: (614) 318-2662
INTERNET: WWW.CHIPOTLE.COM

COPYRIGHT 2024
THIS DRAWING IS AN INSTRUMENT OF SERVICE AND AS SUCH REMAINS THE PROPERTY OF CHIPOTLE MEXICAN GRILL, INC. PERMISSION FOR USE OF THIS DOCUMENT IS LIMITED AND CAN BE EXTENDED ONLY BY WRITTEN AGREEMENT WITH CHIPOTLE MEXICAN GRILL, INC.

PROJECT INFORMATION:

STORE NO.: 4757
"ANDERSON IN"
S SCATTERFIELD RD & 59TH STREET
ANDERSON, IN 46013

SEAL:

PROJECT NO. 2022-0494
DRAWN BY RDB
CHECKED BY

ISSUE RECORD:
12/12/2023 PERMIT SET
06/19/2024 BID SET
07/24/2024 CONSTRUCTION SET

REVISIONS:

TITLE: FINISH DETAILS - TILE

SHEET NUMBER: A802

BUILDING CODE:
THE 2014 INDIANA BUILDING CODE BASED ON THE 2012 INTERNATIONAL BUILDING CODE.

- 4. EXISTING CONSTRUCTION:**
- WHEREVER APPLICABLE, PRIOR TO FABRICATION AND CONSTRUCTION, CONTRACTOR SHALL FIELD VERIFY ALL EXISTING STRUCTURES, DIMENSIONS, DETAILS AND ALL EXISTING STRUCTURAL CONNECTIONS AND OTHER CONDITIONS WHERE THEY AFFECT THIS CONSTRUCTION. NOTIFY THE ENGINEER IF THERE ARE ANY DEVIATIONS FROM THE CONTRACT DOCUMENTS. CONSULT WITH THE STRUCTURAL ENGINEER BEFORE MAKING ANY MODIFICATIONS TO THE EXISTING STRUCTURE NOT INDICATED ON THE CONTRACT DOCUMENTS.
- BEFORE PROCEEDING WITH ANY WORK WITHIN THE EXISTING FACILITY, THE CONTRACTOR SHALL BECOME FAMILIAR WITH THE EXISTING STRUCTURE. IT SHALL BE THE CONTRACTOR'S RESPONSIBILITY TO PROVIDE ALL NECESSARY BRACING, SHORING AND OTHER SAFEGUARDS TO MAINTAIN ALL PARTS OF THE EXISTING WORK IN A SAFE CONDITION DURING THE COURSE OF DESIGN AND CONSTRUCTION AND TO TAKE ALL NECESSARY PRECAUTIONS TO PROTECT THE EXISTING WORK WHICH ARE TO REMAIN.
- THE CONTRACTOR SHALL CONSIDER ALL HAZARDOUS DUE TO WELDING WITHIN THE EXISTING FACILITY, INCLUDING FIRE, HARD, TOXIC SMOKE, HAZARD AND DISRUPTION OF MEMBERS UNDER LOAD. VERIFY THE PRESENCE OF ANY TOXIC MATERIALS PRIOR TO BIDDING THE WORK OR SUBMITTAL OF FINAL PRICE.

- 5 REINFORCED CONCRETE:**
5.1 DESIGN CODE: BUILDING CODE REQUIREMENTS FOR STRUCTURAL CONCRETE (ACI 318), LATEST ADOPTION.
5.2 CONCRETE MIXES SHALL BE DESIGNED PER ACI 301 USING THE FOLLOWING:
PORTLAND CEMENT CONFORMING TO ASTM C150 OR C595
FLY ASH CONFORMING TO ASTM C618
SLAG CONFORMING TO ASTM C989
SILICA FUME CONFORMING TO ASTM C1240.
AGGREGATE CONFORMING TO ASTM C33
ADMITTURES CONFORMING TO ASTM C494, C1017, AND C260. DO NOT USE CALCIUM CHLORIDE OR ADMIXTURES CONTAINING CALCIUM CHLORIDE.
CONCRETE SHALL BE READY-MIXED IN ACCORDANCE WITH ASTM C94.
5.3 MATERIAL STRENGTHS:
5.3.1 PROVIDE THE FOLLOWING CONCRETE PROPERTIES:

DESCRIPTION	COMPRESSIVE STRENGTH (f'c) AT 28 DAYS	MAX AGGREGATE SIZE	SLUMP ²	MAX WATER TO CEMENT RATIOS (W/C) ³
INTERIOR SLABS ON GRADE	4000 PSI	¾"	3" ± 1"	0.43
ANY CONCRETE SUBJECT TO FREEZE-THAW CYCLES (5% ENTRAINED AIR ¹)	4500 PSI	¾"	4" ± 1"	0.45

³ THESE W/C RATIOS MAY BE LOWER THAN NECESSARY TO PROVIDE THE SPECIFIED STRENGTHS.

- 5.3.2 REINFORCING STEEL: ALL OTHER BARS, STIRRUPS AND TIES ASTM A615, GR. 60
WELD WIRE FABRIC AS A1064
- 5.4 PLACEMENT OF CONCRETE AND REINFORCEMENT SHALL BE IN ACCORDANCE WITH ACI AND CRSI STANDARDS.
- 5.5 CLEAN REINFORCEMENT OF LOOSE RUST, MILL SCALE, EARTH, ICE, AND OTHER FOREIGN MATERIALS THAT REDUCE BOND TO CONCRETE.
- 5.6 FOLLOWING CONCRETE COVER ON REINFORCING BARS UNLESS SHOWN OTHERWISE ON DRAWINGS:
SLABS ON GRADE CENTER MESH OR BARS IN SLAB
- 5.7 ALL WELDED WIRE FABRIC SHALL BE TRANSPORTED AND DELIVERED IN FLAT SHEETS.
- 5.8 MAINTAIN CONCRETE IN A CONTINUOUSLY DAMP AND WET CONDITION FOR NOT LESS THAN 7 DAYS AFTER PLACING.
PROTECT FROM MOISTURE LOSS WITH SHEETING OR SPRAY-ON MEMBRANE MEETING ASTM C309 AND COMPATIBLE WITH FLOOR COVERINGS
- 5.9 FINISHING REQUIREMENTS ARE AS FOLLOWS (REFER TO ACI 301):
SMOOTH RUBBED FINISH ON EXPOSED FORM SURFACES.
FINISH TROWEL FINISH ON INTERIOR SLABS AND SLABS TO RECEIVE FINISH FLOORING.
- 5.10 DO NOT FIELD BEND BARS PARTIALLY EMBEDDED IN HARDENED CONCRETE UNLESS SPECIFICALLY INDICATED OR ACCEPTED BY THE ENGINEER.
- 5.11 IN SLABS PROVIDE (2) #4x4-0" DIAGONAL BARS AT 45 DEGREES AT ALL CORNERS OF OPENINGS AND RE-ENTRANT CORNERS.
- 5.12 COLD WEATHER CONCRETING SHALL FOLLOW PROCEDURES IN ACI 306.
- 5.13 HOT WEATHER CONCRETING SHALL FOLLOW PROCEDURES IN ACI 305.
- 5.14 FORMWORK SHALL REMAIN IN PLACE UNTIL CONCRETE HAS ATTAINED A MINIMUM COMPRESSIVE STRENGTH OF 3,000 PSI, UNLESS OTHERWISE DIRECTED BY THE ENGINEER. THE CONTRACTOR SHALL PROVIDE ALL SHORING.
- 5.15 SPECIAL ADDITIONAL REQUIREMENTS FOR SLABS ON GRADE:
DESIGN STANDARD: GUIDE FOR CONCRETE FLOOR AND SLAB CONSTRUCTION (ACI 302.1)
REFER TO GEOTECHNICAL REPORT FOR VAPOR BARRIER, ENGINEERED FILL AND SUBGRADE COMPACTION REQUIREMENTS
- 5.15.1 PAD ADJOINING WELDED WIRE FABRIC AT LEAST TWO FOOT MESHERS.
- 5.15.2 SEE DRAWINGS FOR LOCATIONS OF SLAB CONTROL JOINTS
- 5.15.3 SLAB JOINTS SHALL BE FILLED WITH AN ACCEPTED MATERIAL AS LATE AS POSSIBLE, PREFERABLY AT LEAST 4 TO 6 WEEKS AFTER THE SLAB HAS BEEN CAST. PRIOR TO FILLING, REMOVE ALL DEBRIS FROM THE SLAB JOINTS. FILL IN ACCORDANCE WITH THE MANUFACTURER'S RECOMMENDATIONS.
- 5.15.4 SEE ARCHITECTURAL DRAWINGS FOR EXACT LOCATIONS OF DEPRESSED SLAB AREAS AND DRAINS. SLOPE SLAB TO DRAINS WHERE SHOWN.
- 5.15.7 FINISH TOLERANCE OF ALL SLABS SHALL BE IN ACCORDANCE WITH ACI 302.1 R.

- 6 WOOD:**
6.1 DESIGN CODE: NATIONAL DESIGN SPECIFICATION (NDS) FOR WOOD CONSTRUCTION (AF&PA), LATEST ADOPTION.
6.2 MATERIALS (FOLLOWING INDICATE MINIMUM GRADES UNO ON DRAWINGS):

DESCRIPTION		SPECIES & GRADE		DESIGN VALUES (PSI)			E (x10 ⁶)	COMMENTS
				Fb	FcL	Ft		
FRAMING LUMBER	Dimensional Lumber (2"-4")	SPRUCE-PINE-FIR	NO. 2	875	425	1150	1.4	POSTS
	Timbers (5"x5" and larger)	SPRUCE-PINE-FIR	NO. 2	500	425	500	1.0	POSTS
	Dimensional Lumber (2"-4")	SPRUCE-PINE-FIR	NO. 2	875	425	1150	1.4	JOISTS, BEAMS AND LINTELS
	Timbers (5"x5" and larger)	SPRUCE-PINE-FIR	NO. 2	600	425	425	1.0	BEAMS

- 6.3 ALL LUMBER CONNECTORS TO BE SUPPLIED BY USP OR SIMPSON STRONG-TIE. WHERE LUMBER CONNECTORS ARE TO BE USED BUT ARE NOT CALLED OUT IN THESE DRAWINGS THEY ARE TO BE DESIGNED AND SUPPLIED BY USP OR SIMPSON STRONG-TIE FOR THE REACTION SHOWN ON THESE DRAWINGS. WHEN USING LUMBER CONNECTORS FILL ALL NAIL HOLES TO ACHIEVE PUBLISHED VALUE. WHERE MORE STRINGENT, THESE DRAWINGS SUPERSEDE DIRECTIONS IN PRODUCT CATALOG BUT REFER TO PRODUCT CATALOG FOR TYPICAL INSTALLATION INSTRUCTIONS.
- 6.4 THE MEMBERS AND COMPONENTS SHALL NOT BE CUT, NOTCHED, DRILLED OR OTHERWISE ALTERED IN ANY WAY WITHOUT THE WRITTEN APPROVAL OF THE TRUSS SUPPLIER'S STRUCTURAL ENGINEER.
- 6.5 COORDINATE MECHANICAL EQUIPMENT LOADS AND LOCATIONS WITH MECHANICAL/ARCHITECTURAL DRAWINGS AND MECHANICAL CONTRACTOR.

ABBREVIATIONS			
ACI	AMERICAN CONCRETE INSTITUTE	CRSI	CONCRETE REINFORCING STEEL INSTITUTE
AF&PA	AMERICAN FOREST & PAPER ASSOCIATION	OSHA	OCCUPATIONAL SAFETY AND HEALTH ADMINISTRATION
APA	ENGINEERED WOOD ASSOCIATION	WTCA	WOOD TRUSS COUNCIL OF AMERICA
ASTM	AMERICAN SOCIETY FOR TESTING AND MATERIALS		



CLIENT:



COPYRIGHT 2023
THIS DRAWING IS AN INSTRUMENT OF SERVICE AND
AS SUCH REMAINS THE PROPERTY OF CHIPOTLE
MEXICAN GRILL, INC.. PERMISSION FOR USE OF THIS
DOCUMENT IS LIMITED AND CAN BE EXTENDED ONLY
BY WRITTEN AGREEMENT WITH CHIPOTLE MEXICAN
GRILL, INC..

PROJECT INFORMATION:

STORE NO.: 4757
"HUDSONVILLE, MI"
S SCATTERFIELD RD
ANDERSON, IN 46013

SEAL



DATE: 07-23-2024

PROJECT NO.	230925
DRAWN BY	TAH/TJM
CHECKED BY	TJM

ISSUE RECORD:



12.12.23	PERMIT SET
05.20.24	BID SET
07.24.24	CONSTRUCTION SET

 REVISIONS:

TITLE

SHEET NUMBER

S000

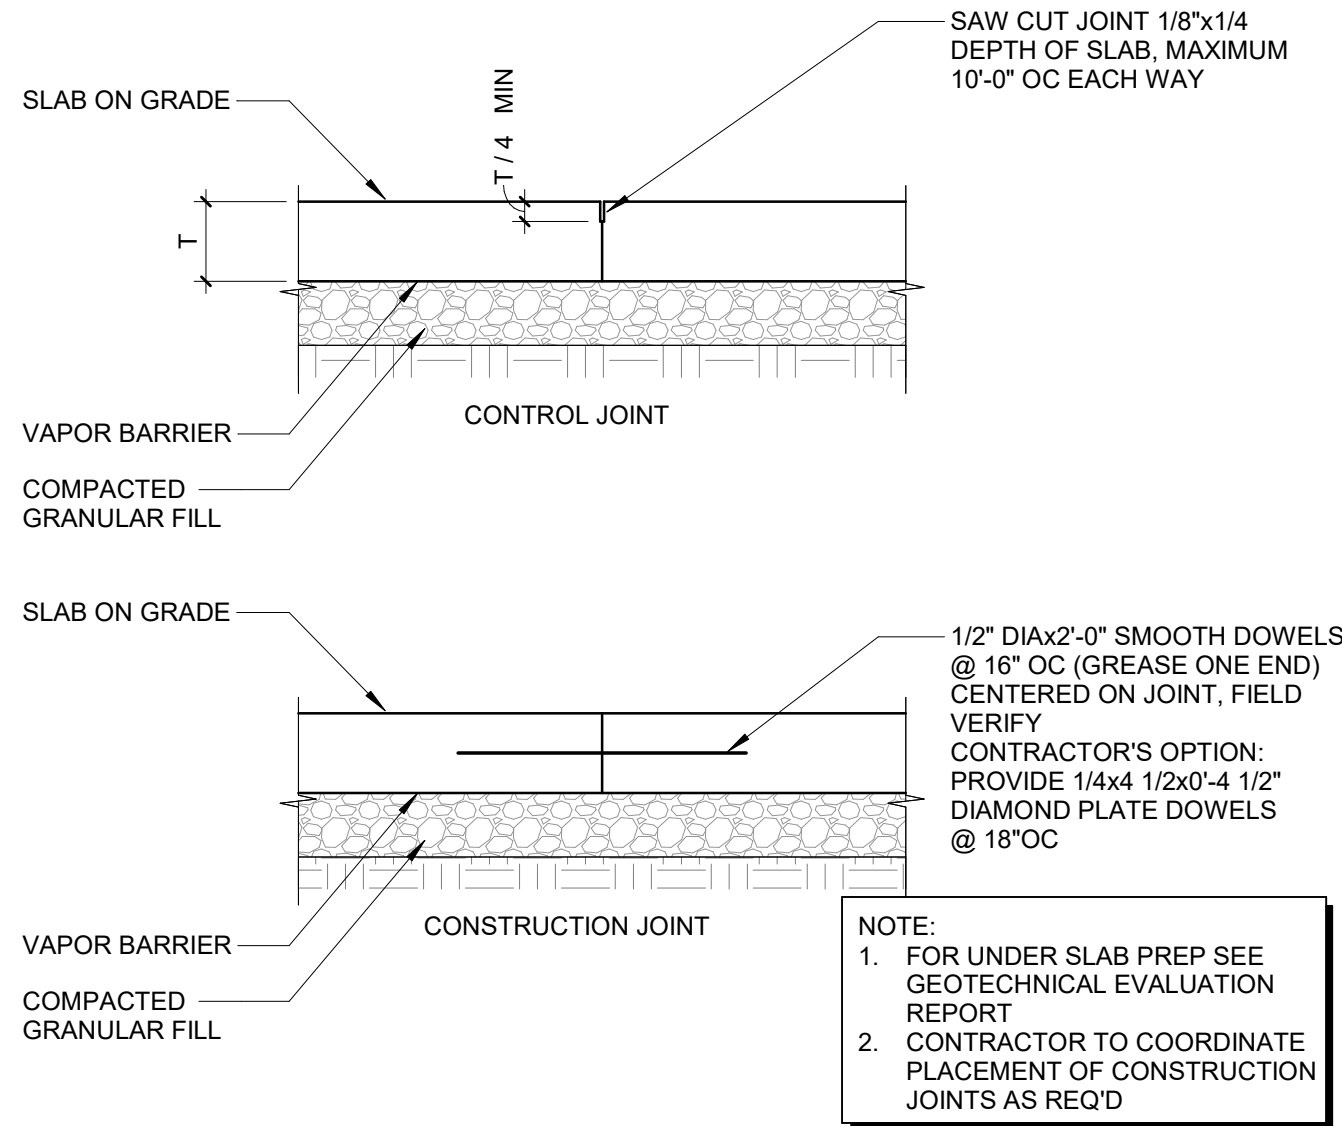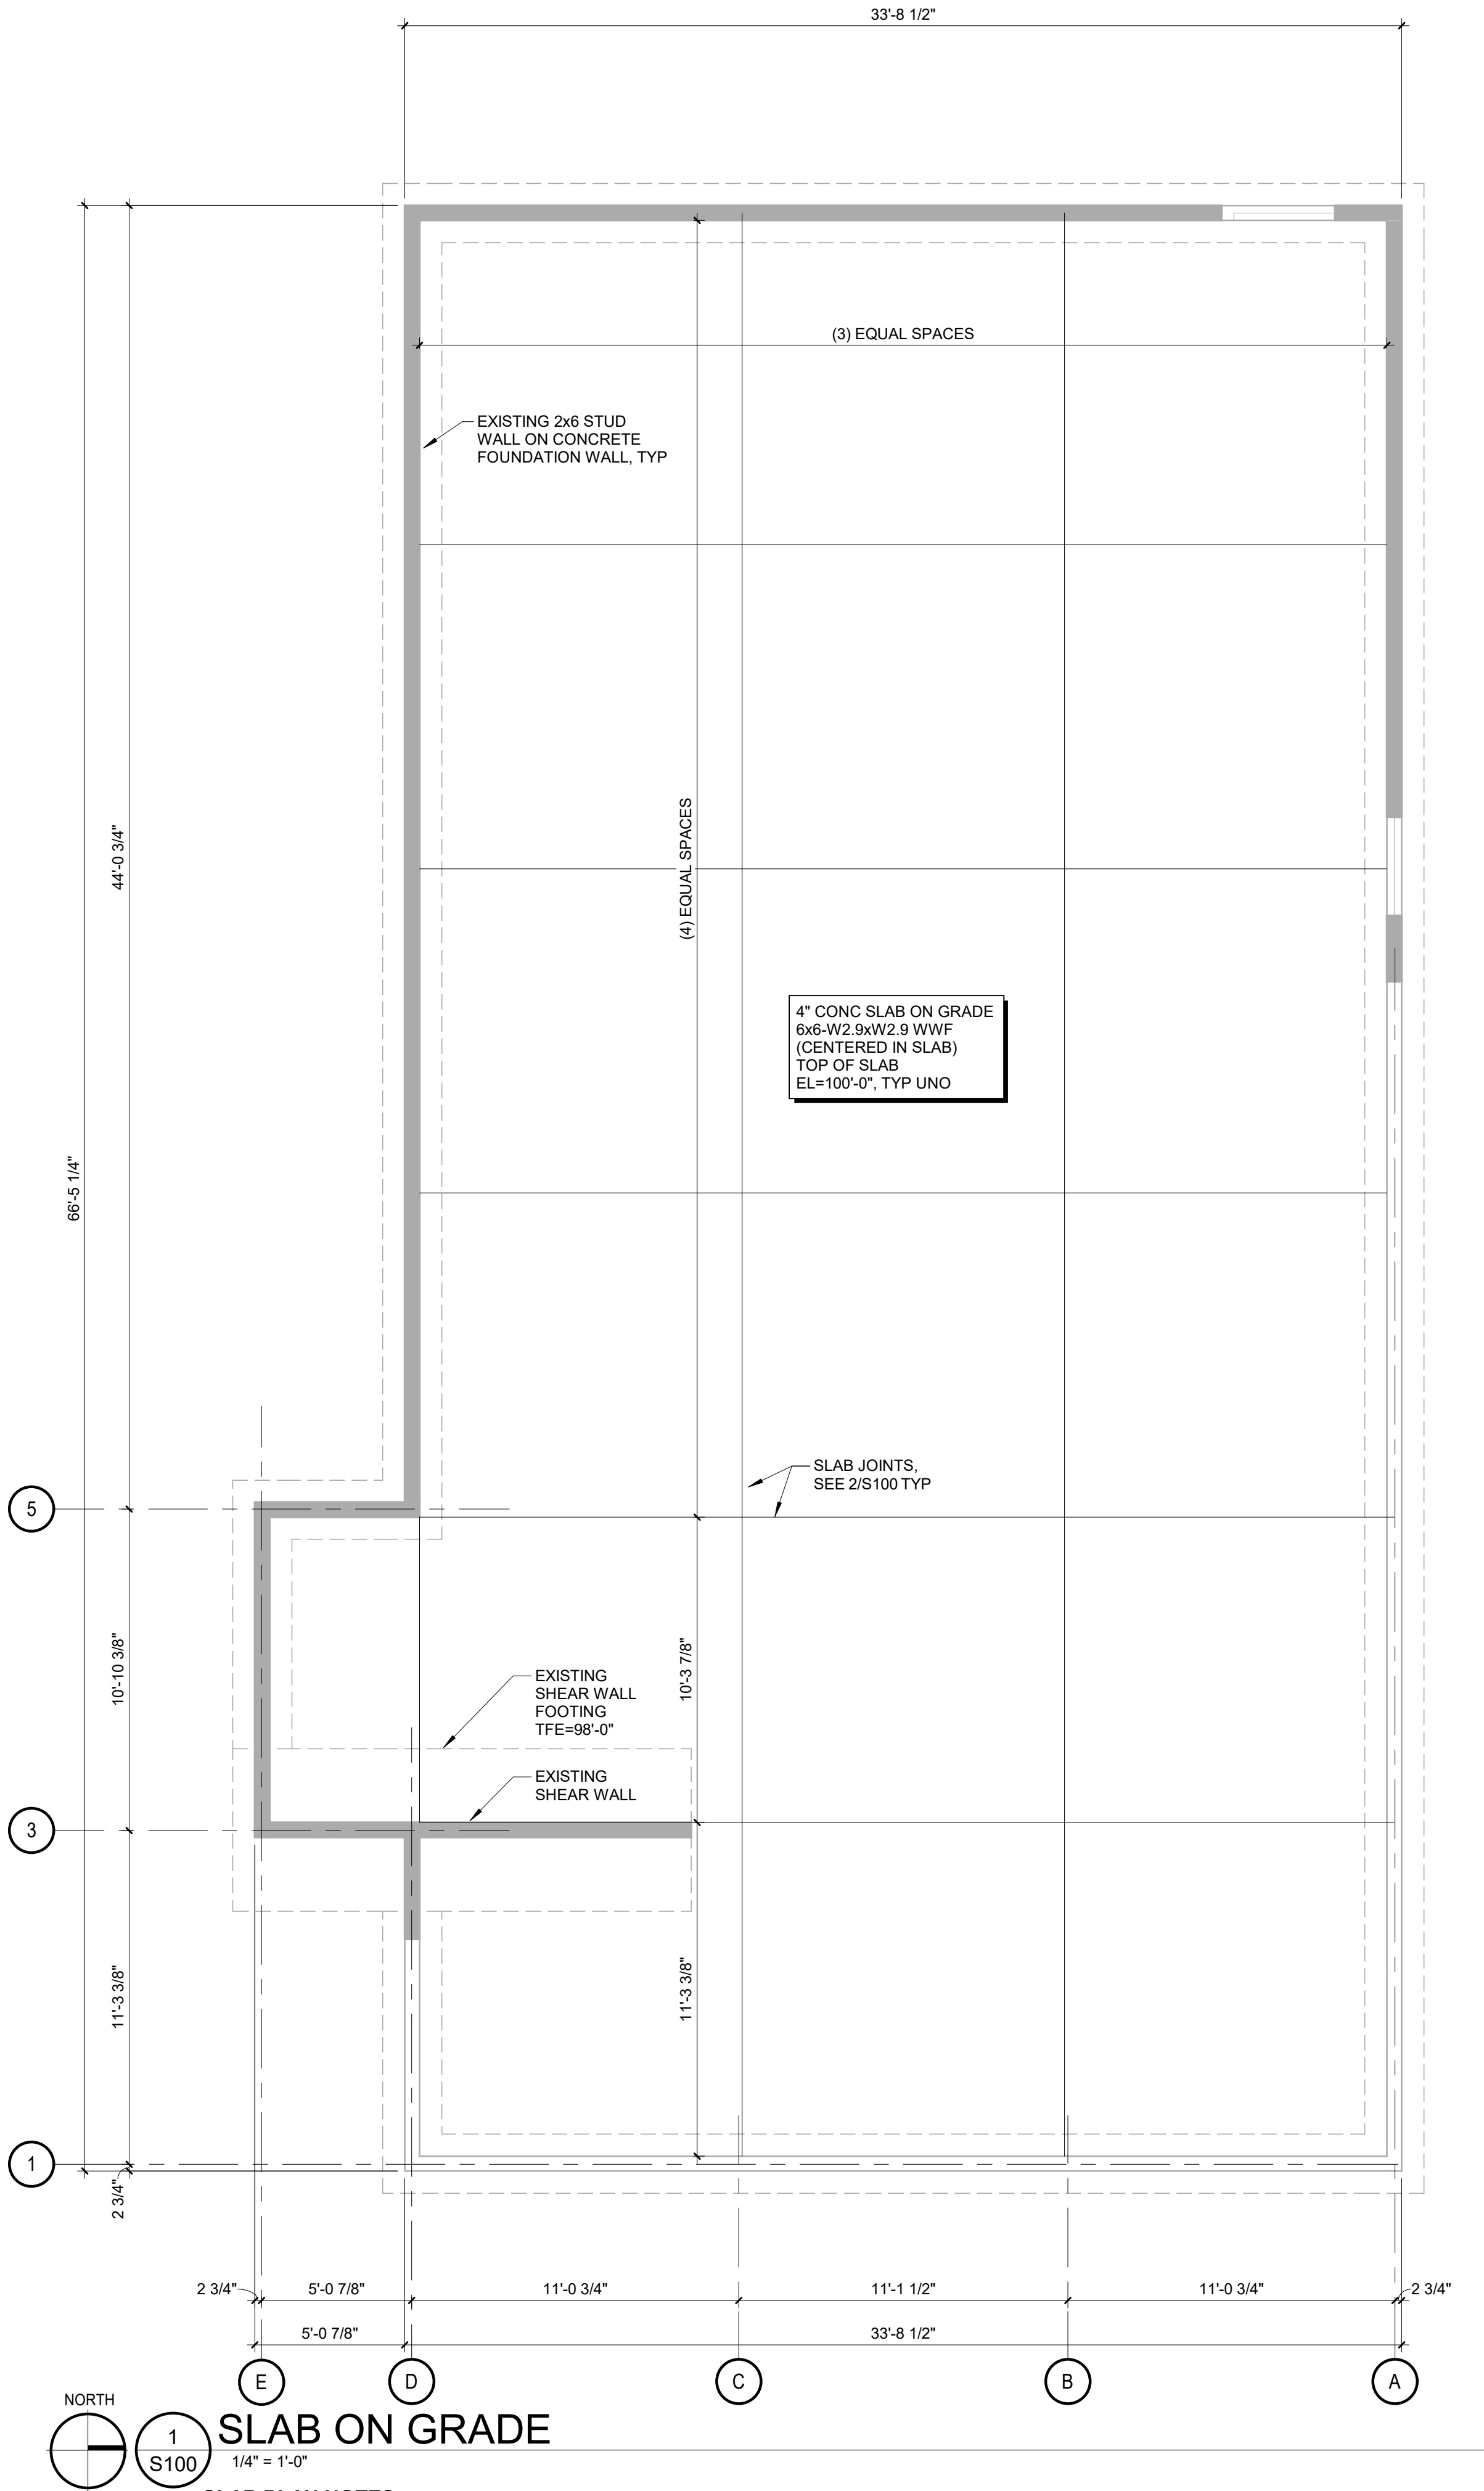

2 INTERIOR SLAB JOINTS
1" = 1'-0"

CONSULTANT:

VAA, LLC
2300 Berkshire Lane N, Suite 200
Plymouth, MN 55441

763.555.9100
www.vaaeng.com

CLIENT:

CHIPOTLE MEXICAN GRILL, INC.
PO BOX 182966
COLUMBUS, OH 43218-2966
TELEPHONE: (614) 315-2652
INTERNET: WWW.CHIPOTLE.COM

COPYRIGHT 2023
THIS DRAWING IS AN INSTRUMENT OF SERVICE AND AS SUCH REMAINS THE PROPERTY OF CHIPOTLE MEXICAN GRILL, INC. PERMISSION FOR USE OF THIS DOCUMENT IS LIMITED AND CAN BE EXTENDED ONLY BY WRITTEN AGREEMENT WITH CHIPOTLE MEXICAN GRILL, INC.

PROJECT INFORMATION:

STORE NO.: 4757
"HUDSONVILLE, MI"
S SCATTERFIELD RD
ANDERSON, IN 46013

SEAL:

DATE: 07-23-2024

PROJECT NO. 230925
DRAWN BY TAH/TJM
CHECKED BY TJM

ISSUE RECORD:

12.12.23	PERMIT SET
05.20.24	BID SET
07.24.24	CONSTRUCTION SET







REVISIONS:

TITLE:

SLAB ON GRADE
PLAN AND DETAILS

SHEET NUMBER:

S100

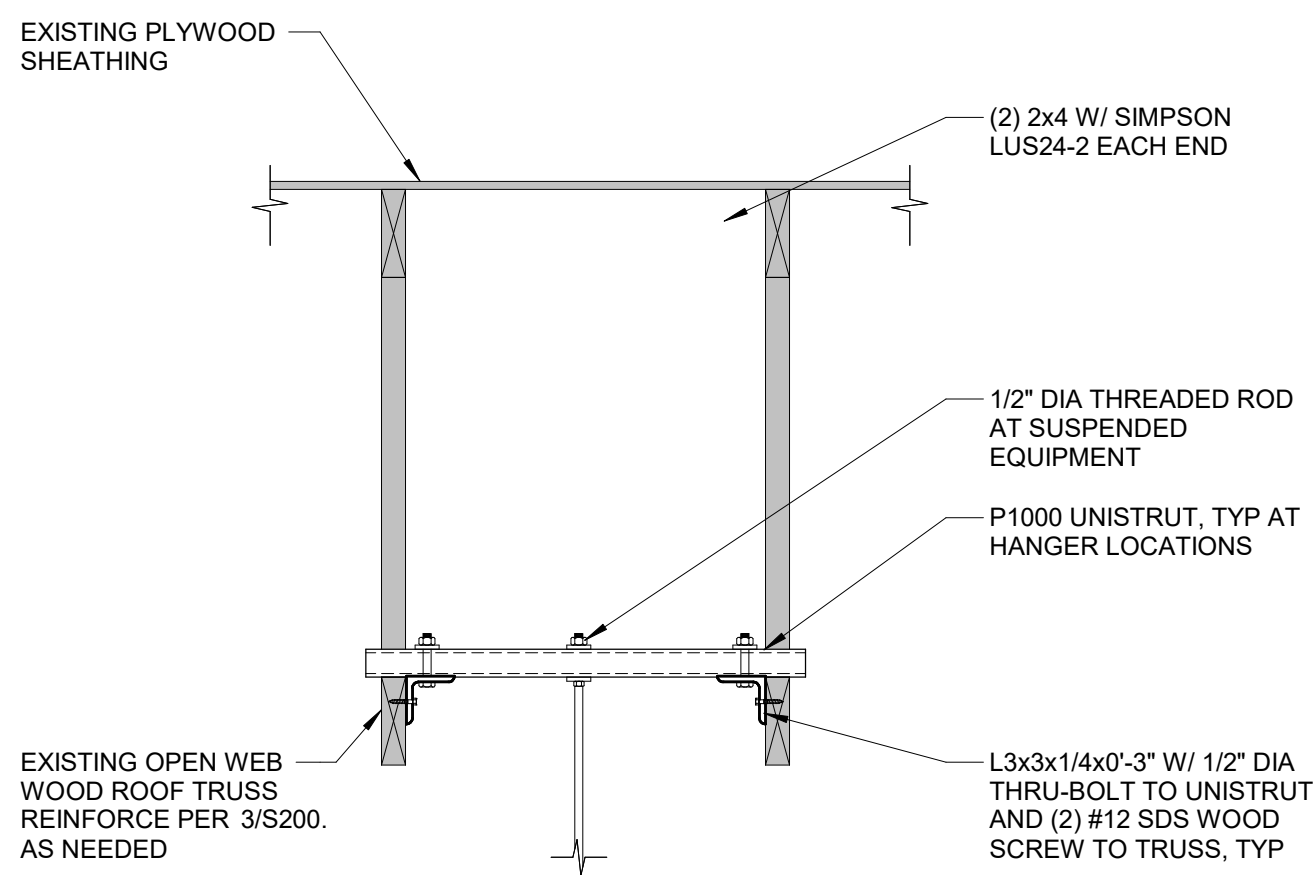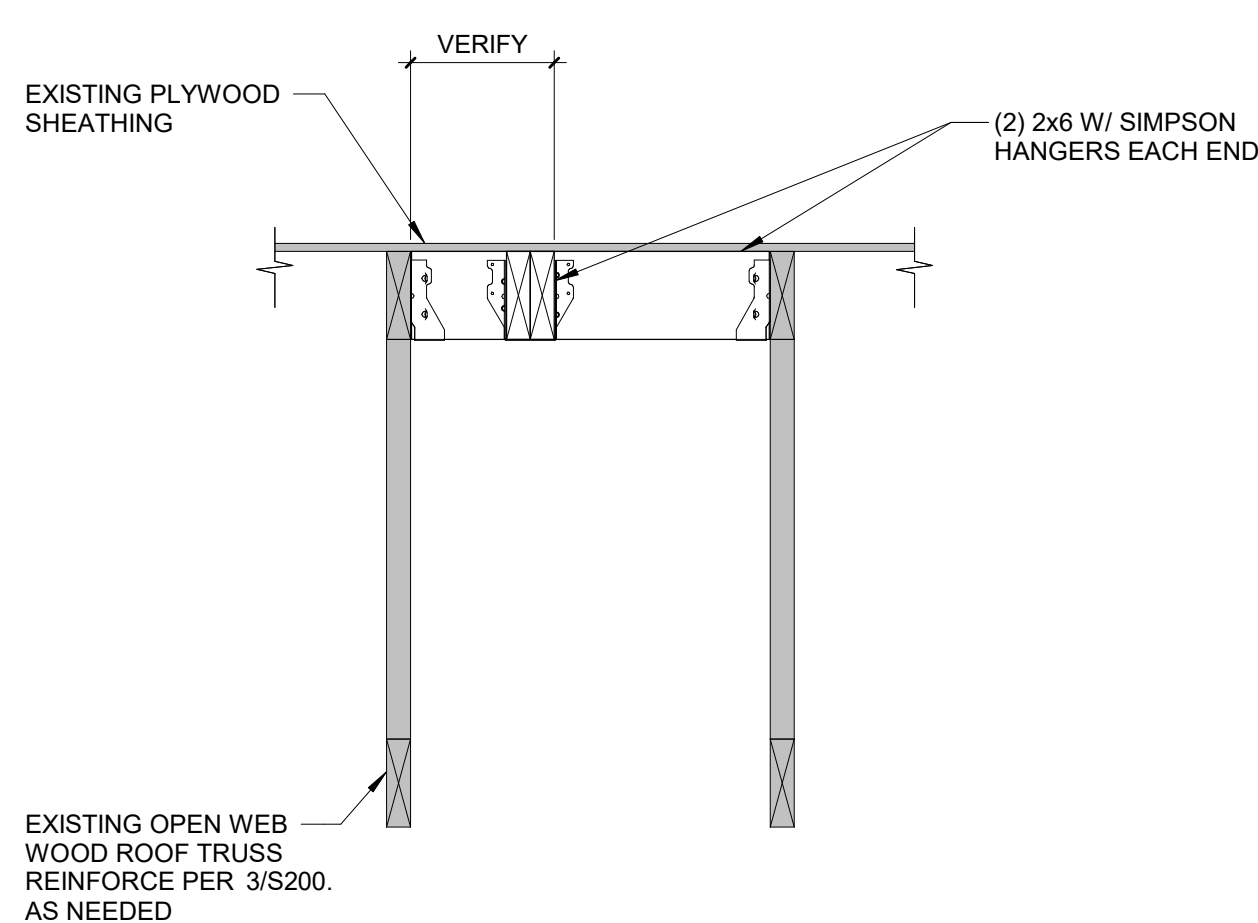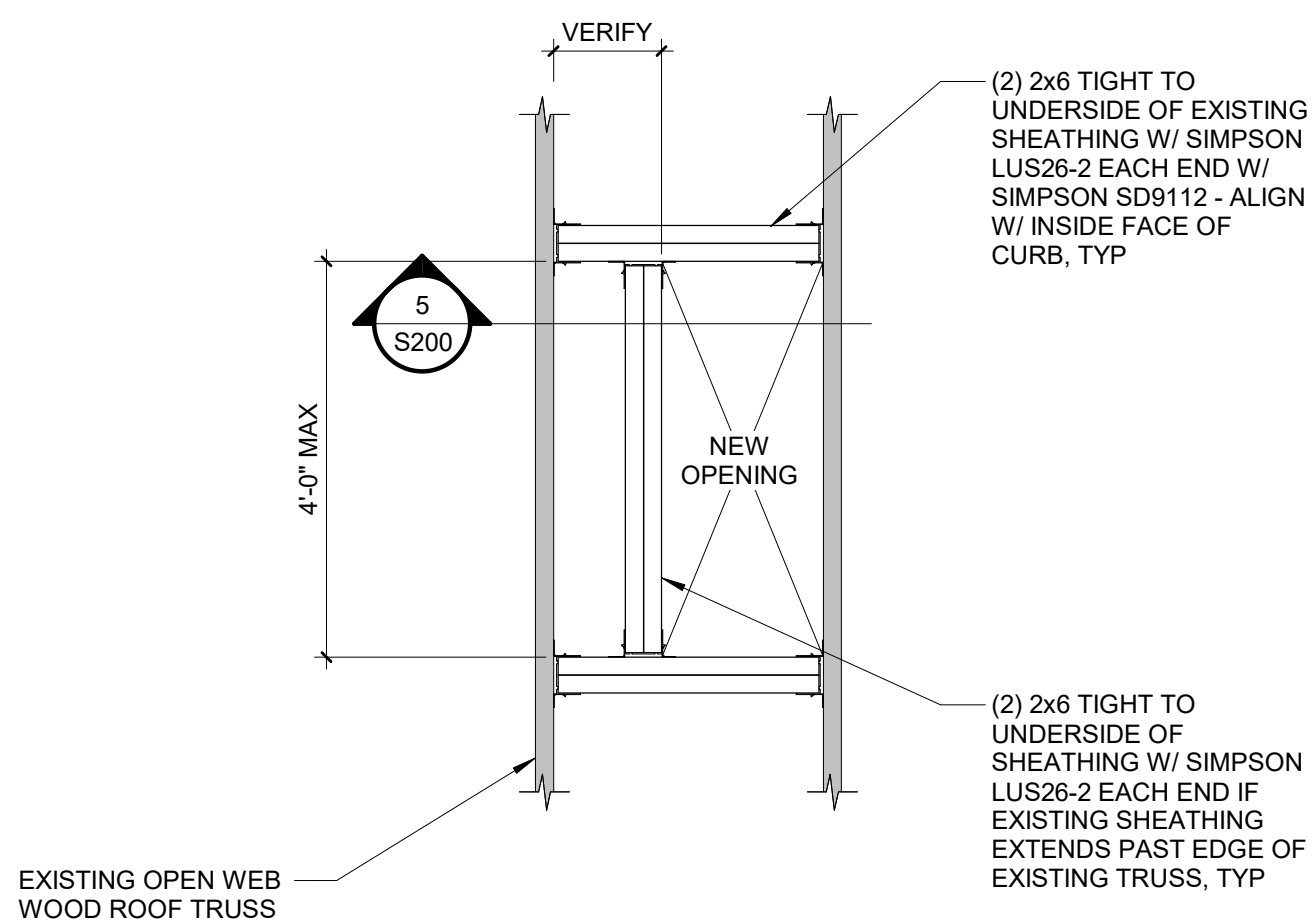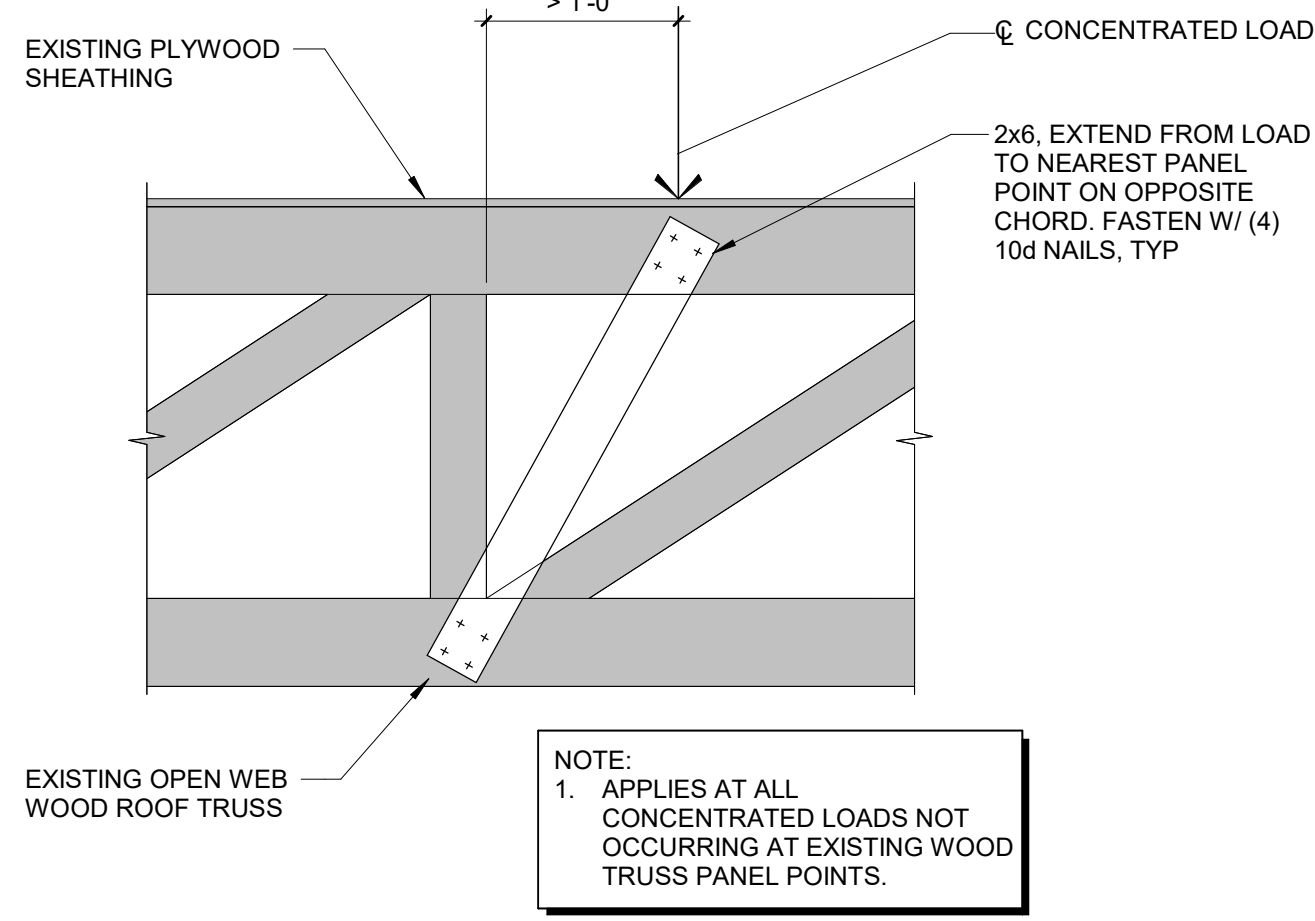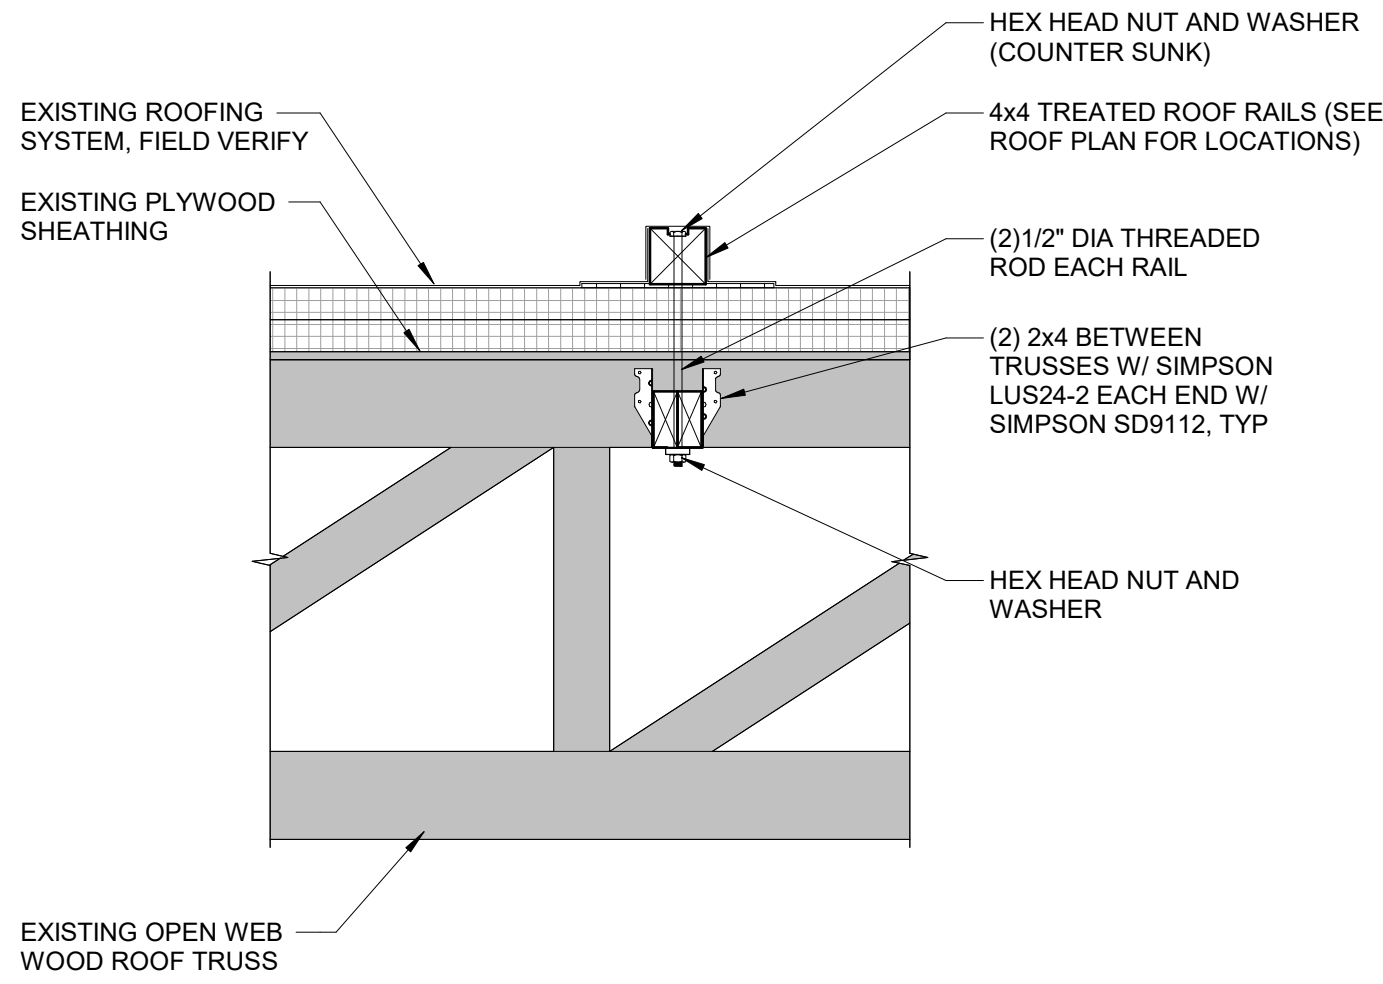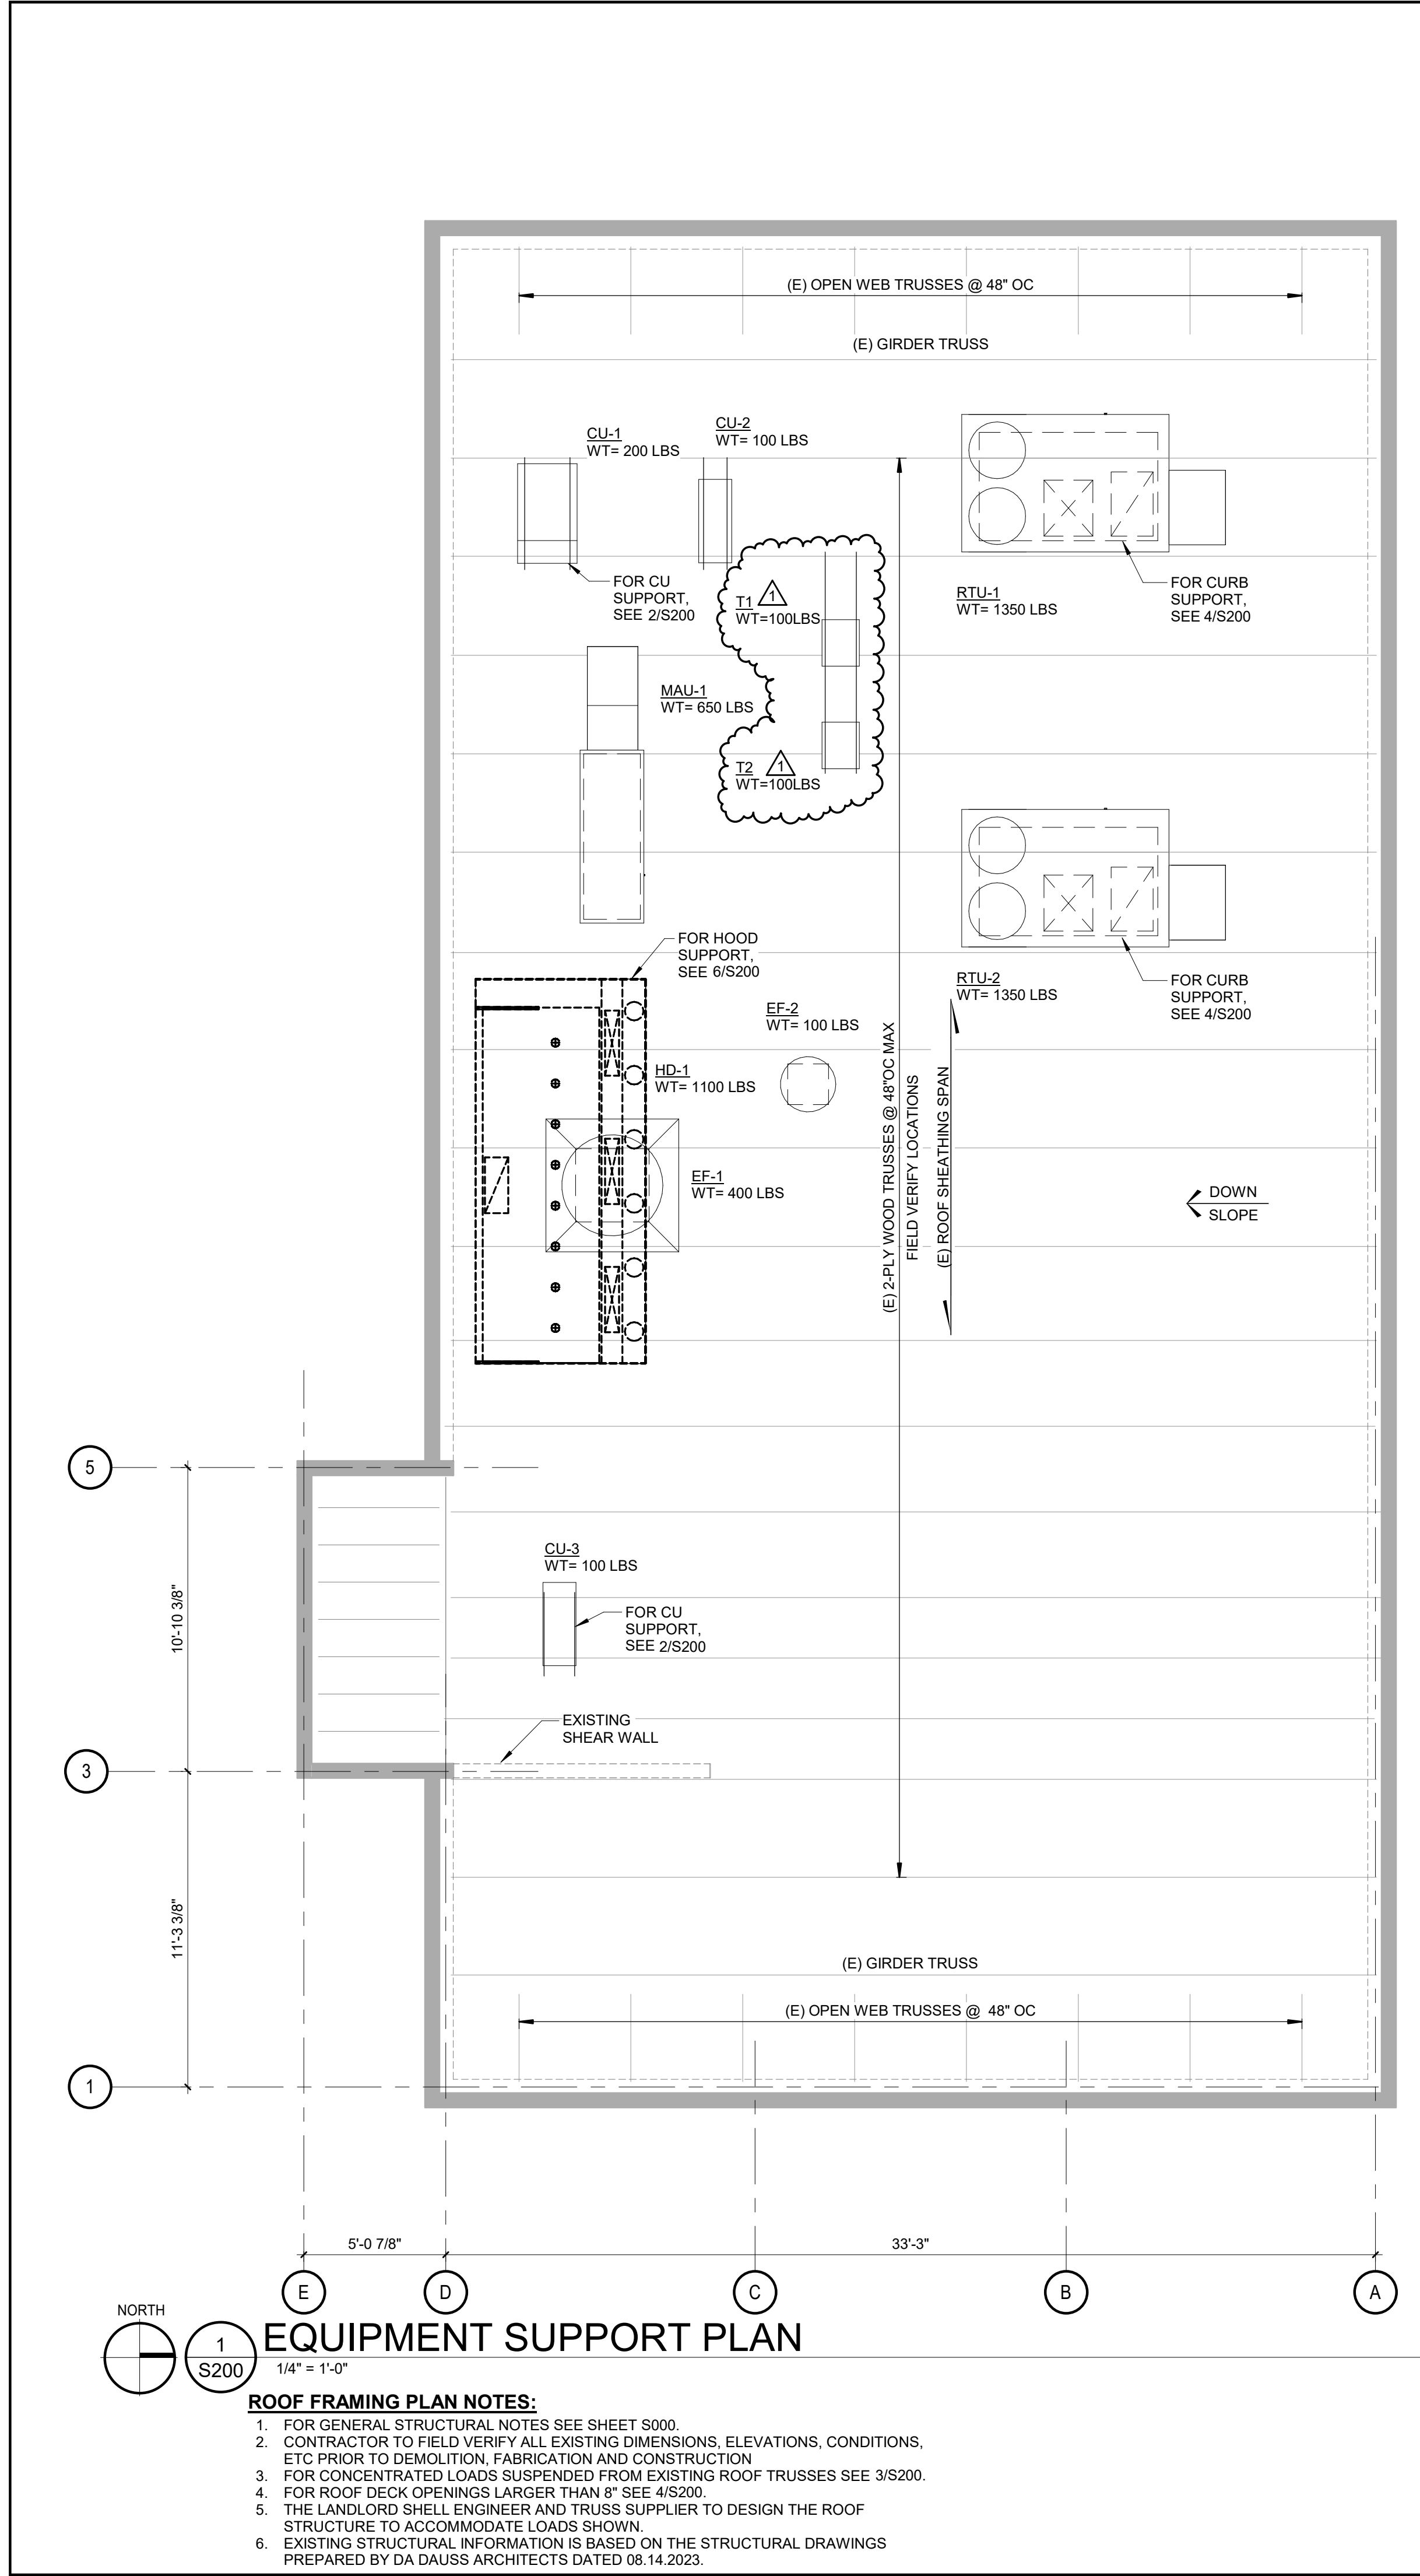

CONSULTANT:

VAA
VAA, LLC
2300 Berkshire Lane N, Suite 200
Plymouth, MN 55441
763.555.9100
www.vaaeng.com

CLIENT:

CHIPOTLE MEXICAN GRILL
CHIPOTLE MEXICAN GRILL, INC.
PO BOX 182966
COLUMBUS, OH 43218-2966
TELEPHONE: (614) 315-2652
INTERNET: WWW.CHIPOTLE.COM

COPYRIGHT 2023
THIS DRAWING IS AN INSTRUMENT OF SERVICE AND AS SUCH REMAINS THE PROPERTY OF CHIPOTLE MEXICAN GRILL, INC. PERMISSION FOR USE OF THIS DOCUMENT IS LIMITED AND CAN BE EXTENDED ONLY BY WRITTEN AGREEMENT WITH CHIPOTLE MEXICAN GRILL, INC.

PROJECT INFORMATION:

STORE NO.: 4757
"HUDSONVILLE, MI"
S SCATTERFIELD RD
ANDERSON, IN 46013

SEAL:

MARK D. BIELKE
REGISTERED PROFESSIONAL ENGINEER
NO. 100109229
STATE OF INDIANA
DATE: 07-23-2024

PROJECT NO. 230925
DRAWN BY TAH/TJM
CHECKED BY TJM

ISSUE RECORD:

12.12.23	PERMIT SET
05.20.24	BID SET
07.24.24	CONSTRUCTION SET

REVISIONS:

1	05.20.24	RTU REVISION
---	----------	--------------

TITLE:

EQUIPMENT SUPPORT PLAN AND DETAILS

SHEET NUMBER:

S200

SECTION 15732 - PACKAGED ROOFTOP AIR-CONDITIONING UNITS
PART 1 - GENERAL
1.1 SECTION REQUIREMENTS
A. Submittals: Product Data and Shop Drawings.
B. Comply with ASHRAE 15.
C. EER: Equal to or greater than prescribed by the energy code adopted by the Authority Having Jurisdiction.
D. Warranties: Submit a written warranty, signed by the manufacturer, agreeing to the repair or replacement of components that fail within 5 years of Substantial Completion.
PART 2 - PRODUCTS
2.1 PACKAGED UNITS, 5 TO 20 TONS
A. Factory assembled and tested, consisting of compressors, condensers, evaporator coils, condenser and evaporator fans, refrigeration and temperature controls, filters, and dampers.
1. Refer to Rooftop Heating/Cooling Unit Schedule on drawing M600 for capacities, and manufacturers.
2. Evaporator Fans: Belt or direct driven, forward curved centrifugal.
3. Exhaust/Relief Fans: Direct drive, forward curved centrifugal or propeller.
4. Condenser Fans: Direct drive propeller.
5. Refrigerant Coils: Aluminum fins and copper coil.
6. Compressors: Serviceable hermetic or fully hermetic, with safety controls, hot gas bypass, and timed off controls.
7. Heat Exchangers: Gas fired, with gas controls, electronic ignition, high limit cutout, and forced draft proving switch.
8. Economizer controls (Comparative Enthalpy, 100% capacity).
9. Smoke Detectors: Photoelectric in supply and/or return as called for in schedule on sheet M600.
10. Operating Controls: Two stage heating and two stage cooling on units 7-1/2 tons and over.
11. Roof curb.
12. Control Wiring from T-stat to rooftop unit: Shall be 18ga / 7 conductor, rated for plenum applications.
13. Control Wiring from T-stat to remote sensor: Shall be a separate 18ga / 2 conductor shielded, rated for plenum applications.
PART 3 - EXECUTION
3.1 INSTALLATION
A. Install units level and plumb and firmly anchored.
B. Connect gas piping to burner with pipe same size as gas train inlet, and provide union with sufficient clearance for burner removal and service.
C. Install ducts to termination in roof mounting frames. Terminate ducts through roof structure.
D. Connect units to wiring systems and to ground.
END OF SECTION 15732

SECTION 15810 - DUCTS AND ACCESSORIES
PART 1 - GENERAL
1.1 SECTION REQUIREMENTS
A. Submittals: Product Data for fire and smoke dampers.
B. Comply with NFPA 90A for systems serving spaces more than 25,000 cu. ft. in volume or building Types II, IV, and V construction more than 3 stories in height.
C. Comply with NFPA 90B for systems serving spaces in 1 or 2 family dwellings or serving spaces less than 25,000 cu. ft..
D. Comply with NFPA 96, "Ventilation Control and Fire Protection of Commercial Cooking Operations," for kitchen hood ducts.
E. Comply with UL 181 and UL 181A for ducts and closures.
F. Testing, Adjusting, and Balancing Agency Qualifications: AABC certified (to be furnished by Tenant).
PART 2 - PRODUCTS
2.1 DUCTS
A. Spiral Duct: Spiral Lock Seam, without insulation, G90 galvanized finish, ASTM A-653/924
1. Basis of Design Manufacturers: Lindab SPIROsafe, alternates to the basis of design must be submitted for review.
2. Fittings: Factory produced standing seam construction with internal sealing. Fittings with a major axis of 36" or smaller shall be 20 gauge. Fittings with a major axis of 37"-48" shall be 18 gauge.
B. Galvanized Steel Sheet: Forming steel, ASTM A 653/653M, G90 coating designation.
C. Duct Liner: ASTM C 1071, Type II, with an airstream surface coated with a temperature resistant coating. Thickness: 1-1/2 inch. R-value : 8.
1. Adhesive: ASTM C 916, Type I.
2. Mechanical Fasteners: Galvanized steel pin, length as required to penetrate liner plus a 1/8 inch projection maximum into the airstream.
D. Joint and Seam Tape: Comply with UL 181A.
E. Joint and Seam Sealant: Comply with UL 181A.
F. Rectangular Metal Duct Fabrication: Comply with SMACNA's "HVAC Duct Construction Standard" for metal thickness, reinforcing types and intervals, tie rod applications, and joint types and intervals.
2.2 ACCESSORIES
A. Volume-Control Dampers: Factory fabricated volume control dampers, complete with required hardware and accessories. Single blade and multiple opposed blade, standard leakage rating, and suitable for horizontal or vertical applications.
B. Fire Dampers: Factory-fabricated fire dampers, complete with required hardware and accessories. UL labeled according to UL 555, "Fire Dampers".
C. Flexible Connectors: Flame retardant or noncombustible fabrics, coatings, and adhesives complying with UL 181, Class 1.
D. Flexible Ducts: Factory fabricated, insulated, round duct, with an outer jacket enclosing 2 inch thick, glass fiber insulation, R-value: 6.0, around a continuous inner liner.
PART 3 - EXECUTION
3.1 INSTALLATION
A. Duct System Pressure Class: Construct and install each duct system with 2 inch positive and negative duct pressure classifications.
B. Conceal ducts from view in finished and occupied spaces. Except where noted as exposed.
C. Avoid passing through electrical equipment spaces and enclosures.
D. Support and connect metal ducts according to SMACNA's "HVAC Duct Construction Standard".
E. Install duct accessories according to applicable portions of details of construction as shown in SMACNA standards.
F. Install liner and/or insulation on ductwork per the material schedule on sheet M010.
G. Install volume control dampers in lined duct with methods to avoid damage to liner and to avoid erosion of duct liner.
H. Install fire and smoke dampers according to manufacturer's UL approved written instructions.
I. Install fusible links in fire dampers.
J. Provide saddle taps at tees for exposed ductwork.
3.2 TESTING, ADJUSTING, AND BALANCING
A. The Tenant will supply an independent balance agent to to balance and adjust the HVAC installation. The balance agent will be responsible for any pulley or belt changes required.
B. The GC is to have trained staffed available during the balancing to correct issues noted by the balance agent.
C. The balance agent is to balance airflow within distribution systems, including submains, branches, and terminals to indicated quantities +/- 10%. The hood exhaust system shall be balanced to a tolerance of -0+10% and the make-up air system to a tolerance of -10+0%.
D. The balance agent is to supply a copy of the balance report to the Tenant, engineer and general contractor for review.
END OF SECTION 15810

SECTION 15855 - DIFFUSERS, REGISTERS, AND GRILLES
PART 1 - GENERAL
1.1 SECTION REQUIREMENTS
A. Submittals: None.
PART 2 - PRODUCTS
2.1 OUTLETS AND INLETS
A. All air terminal devices:
1. Refer to Grills, Registers, and Diffusers Schedule for equipment schedule
2. Manufacturer: As scheduled (NO SUBSTITUTIONS)
3. Material: As scheduled.
4. Finish: As scheduled.
5. Mounting: As scheduled.
PART 3 - EXECUTION
3.1 INSTALLATION
A. Coordinate location and installation with duct installation and installation of other ceiling and wall mounted items.
B. Locate ceiling diffusers, registers, and grilles, as indicated on the architectural "reflected ceiling plans." Unless otherwise indicated, locate units in center of acoustical ceiling panels.
END OF SECTION 15855

HVAC MATERIAL SCHEDULE		
CATEGORY	APPLICATION	ALLOWABLE MATERIAL
DUCT	EXPOSED SUPPLY	RECT. LINED OR ROUND AS SHOWN, NO EXPOSED DUCT-SEALING MASTIC
	EXPOSED RETURN	RECTANGULAR, NO EXPOSED DUCT-SEALING MASTIC
	EXPOSED GEN. EXHAUST	RECTANGULAR OR ROUND AS SHOWN, NO EXPOSED DUCT-SEALING MASTIC
	CONCEALED, SUPPLY	RECT. OR ROUND AS SHOWN, LINED OR INSULATED
	CONCEALED, RETURN	RECT. OR ROUND AS SHOWN, LINED OR INSULATED
	CONCEALED, GEN. EXHAUST	RECT. OR ROUND AS SHOWN
	CONCEALED, TYPE I HOOD EXHAUST	RECTANGULAR 16 GA. BLACK IRON W/ WRAP OR UL 1978 FACTORY-MANUFACTURED DUCT W/ WRAP (SUBMIT SHOP DRAWINGS FOR FACTORY-MANUFACTURED DUCT PRIOR TO ORDERING FOR APPROVAL)

HVAC GENERAL NOTES

 
- A GENERAL NOTES APPLY TO HVAC SHEETS.
B WORK SHALL COMPLY WITH STATE AND LOCAL CODE REQUIREMENTS AS APPROVED AND AMENDED BY THE AUTHORITY HAVING JURISDICTION, INCLUDING APPLICABLE SECTIONS OF NFPA, THE MECHANICAL CODE, AND ANY INTERIM AMENDMENTS AT THE TIME OF THE PROPOSAL. PURCHASE PERMITS ASSOCIATED WITH THE WORK. OBTAIN INSPECTIONS REQUIRED BY CODE. SEE ARCHITECTURAL SHEETS FOR THE PREVAILING CODES.
C CONTRACTOR AND SUBCONTRACTORS SHALL REVIEW A COMPLETE SET OF THE CONSTRUCTION DOCUMENTS.
D COORDINATE WORK WITH THE WORK OF OTHER TRADES, EQUIPMENT FURNISHED BY OTHERS, REQUIREMENTS OF THE OWNER, AND OF THE EXISTING CONDITIONS AT THE PROJECT SITE.
E DRAWINGS FOR THE MECHANICAL WORK ARE DIAGRAMMATIC, SHOWING THE GENERAL LOCATION, TYPE, LAYOUT, AND EQUIPMENT REQUIRED. THE DRAWING SHALL NOT BE SCALED FOR EXACT MEASUREMENTS; REFER TO ARCHITECTURAL DRAWINGS FOR DIMENSIONS. REFER TO MANUFACTURER'S STANDARD INSTALLATION DRAWINGS FOR EQUIPMENT CONNECTIONS AND INSTALLATION REQUIREMENTS. PROVIDE DUCTWORK, CONNECTIONS, OFFSETS, ACCESSORIES, AND MATERIALS NECESSARY FOR A COMPLETE SYSTEM.
F DUCT DIMENSIONS ON PLANS INDICATE DIMENSIONS OF INTERNAL FREE AREA.
G PERFORATED CEILING DIFFUSERS SHALL BE 4-WAY UNLESS NOTED OTHERWISE.
H COORDINATE ROOF WORK WITH THE OWNER'S CONSTRUCTION MANAGER PRIOR TO CONSTRUCTION.
I UNLESS NOTED OTHERWISE RECTANGULAR DUCT ELBOWS GREATER THAN 45° SHALL BE MITERED ELBOWS WITH DOUBLE-THICKNESS TURNING VANES AND RECTANGULAR DUCT ELBOWS 45° OR LESS SHALL BE RADIUSED ELBOWS WITH AN INSIDE RADIUS OF AT LEAST 1/2 THE WIDTH OF THE DUCT.
J REPLACE AIR FILTERS WITH NEW, CLEAN MERV 8 AIR FILTERS AT TURNOVER.
K THE TERM "FURNISH" MEANS SUPPLY AND DELIVER TO THE PROJECT SITE, READY FOR UNLOADING, UNPACKING, ASSEMBLY, INSTALLATION, AND SIMILAR OPERATIONS. THE TERM "INSTALL" DESCRIBES THE OPERATIONS AT THE PROJECT SITE INCLUDING THE ACTUAL UNLOADING, UNPACKING, ASSEMBLY, ERECTING, PLACING, ANCHORING, APPLYING, WORKING TO DIMENSION, FINISHING, CURING, PROTECTING, CLEANING, AND SIMILAR OPERATIONS. THE TERM "PROVIDE" MEANS TO FURNISH AND INSTALL, COMPLETE AND READY FOR THE INTENDED USE.
L INSTALL LABELING CALLED FOR IN THE MECHANICAL DRAWINGS USING ENGRAVED PHENOLIC PLATES (WHITE WITH BLACK LETTERING).
M PROVIDE P3000 12 GA. UNISTRUT WITH PG FINISH FOR DUCT SUPPORTS AND OTHER UNISTRUT IN AREAS EXPOSED TO VIEW. SLOTTED UNISTRUT AND OTHER UNISTRUT WITH HOLES IS NOT ACCEPTABLE.


HVAC ABBREVIATIONS


AFF ABOVE FINISHED FLOOR
AFG ABOVE FINISHED GRADE
CD CEILING DIFFUSER
CU CONDENSING UNIT
(E) EXISTING
EF EXHAUST FAN
ER EXHAUST REGISTER
EXT'G EXISTING
HD HOOD
MUA MAKEUP AIR UNIT
OBD BLADE DAMPER
RG RETURN GRILLE
RTU ROOFTOP UNIT
SR SUPPLY REGISTER
VSC VARIABLE SPEED CONTROL

COZAS TENANT'S CO2 ALARM SUPPLIER
GC GENERAL CONTRACTOR
HES TENANT'S HVAC EQUIPMENT SUPPLIER
HS TENANT'S HOOD SUPPLIER
KES TENANT'S KITCHEN EQUIPMENT SUPPLIER
TAB TENANT'S TEST AND BALANCE VENDOR
TCC TENANT'S CABLING CONTRACTOR
TDC TENANT'S DUCT CLEANER
TEMS TENANT'S ENERGY MANAGEMENT SYSTEM SUPPLIER
TLS TENANT'S LIGHT/LAMP SUPPLIER
TMB TENANT'S MENU BOARD SUPPLIER
TMS TENANT'S MILLWORK SUPPLIER
TP TENANT'S PHONE SUPPLIER
TPS TENANT'S PANELBOARD SUPPLIER
TRS TENANT'S RAILING SUPPLIER
TSV TENANT'S SIGN VENDOR
TUV TENANT'S UV SANITIZER SUPPLIER
WCS TENANT'S WALK-IN COOLER SUPPLIER
WHS TENANT'S WATER HEATER SUPPLIER

HVAC SYMBOLS


 CEILING DIFFUSER

  
 CEILING-MOUNTED RETURN OR EXHAUST REGISTER

 SUPPLY REGISTER


 RETURN GRILLE

 
 FLEXIBLE DUCT

  MITERED CORNER WITH TURNING VANES
DUCTWORK INTERNAL FREE DIMENSIONS (WIDTH/HEIGHT) RECTANGULAR TO ROUND DUCT TRANSITION


 DUCT-MOUNTED SMOKE DETECTOR

 
 MOTOR-OPERATED DAMPER
MANUAL VOLUME DAMPER

 
 GREASE DUCT CLEANOUT
MITERED CORNER WITHOUT TURNING VANES


 GRIDPOINT THERMOSTAT

 
 GRIDPOINT ZONE SENSOR MODULE

 GRIDPOINT SUPPLY PROBE

   PLAN NOTE: SEE PLAN NOTES LISTED ON THE SAME SHEET FOR NOTE MEANING

 CONNECT TO EXISTING

   EQUIPMENT TAG: SEE EQUIPMENT SCHEDULE ON SHEET M600 FOR EQUIPMENT INFORMATION
AUDIO/VISUAL REMOTE SMOKE DETECTOR ANNUNCIATOR WITH REMOTE KEY OPERATED RESET



Consultant:

4635 Trueman Blvd. Suite 250
Hilliard, Ohio 43026
Phone: (614) 751-9610
Fax: (614) 552-5240
Contact: Cliff Kigar
(614) 328-2033
ckigar@nationalengineering.com

FOR CONSTRUCTION

COPYRIGHT 2024
THIS DRAWING IS AN INSTRUMENT OF SERVICE
AND AS SUCH REMAINS THE PROPERTY OF
CHIPOTLE MEXICAN GRILL, INC.. PERMISSION FOR
USE OF THIS DOCUMENT IS LIMITED AND CAN BE
EXTENDED ONLY BY WRITTEN AGREEMENT WITH
CHIPOTLE MEXICAN GRILL, INC..



CHIPOTLE MEXICAN GRILL, INC.
PO BOX 182566
COLUMBUS, OH 43218-2566
TELEPHONE: (614) 318-2400
INTERNET: WWW.CHIPOTLE.COM

STORE NO.: 4757
ANDERSON
S SCATTERFIELD RD
ANDERSON, IN 46013

Issue Record:
12/12/2023 PERMIT SET
05/20/2024 BID SET
07/24/2024 CONSTRUCTION SET

Revisions:

Drawn: CJK
Checked: JEJ

Project No.
2201198






Contents:

HVAC
SPECIFICATIONS


M010

HVAC PLAN NOTES

- SEE ARCHITECTURAL REFLECTED CEILING PLAN FOR CEILING MOUNTED EQUIPMENT LOCATION. TYPICAL.
- PAINT DUCTWORK VISIBLE THROUGH DINING ROOM SUPPLY REGISTERS AND RETURN GRILL BLACK. TYPICAL.
- ADJUST SUPPLY REGISTERS SO THAT SUPPLY AIR HITS WALL ON OPPOSITE SIDE OF ROOM AT APPROXIMATELY 7' AFF WITH NO DRAFTS FELT IN THE DINING ROOM.
- 26/14 DUCT UP FOR TRANSITION TO RTU-1 RETURN CONNECTION IN ROOF CURB. RTU-1 SHALL HAVE AN INTEGRAL SMOKE DETECTOR MOUNTED IN THE RETURN AIR STREAM. INTERLOCK SMOKE DETECTOR TO RTU-1 OPERATION.
- 26/14 DUCT UP FOR TRANSITION TO RTU-2 RETURN CONNECTION IN ROOF CURB. RTU-2 SHALL HAVE AN INTEGRAL SMOKE DETECTOR MOUNTED IN THE RETURN AIR STREAM. INTERLOCK SMOKE DETECTOR TO RTU-2 OPERATION.
- 28/16 DUCT UP FROM BUILDING SUPPLY THROUGH ROOF. TRANSITION TO RTU-1 SUPPLY CONNECTION IN ROOF CURB.
- 28/16 DUCT UP FROM BUILDING SUPPLY TO RTU-2 SUPPLY CONNECTION. TRANSITION IN ROOF CURB.
- 14/14 DUCT UP THROUGH ROOF. TRANSITION TO MAU-1 SUPPLY CONNECTION IN ROOF CURB.
- 24/10 DUCT UP FROM HOOD THROUGH ROOF TO EF-1 COMPLIANT WITH NFPA 96. PROVIDE RADIUSD ELBOWS WITH AN INSIDE RADIUS OF 0.5W AT ELBOWS IN GREASE DUCT.
- 8/6 DUCT UP THROUGH ROOF TO EF-2.
- 28/6 DUCT DOWN TO MAKEUP AIR PSP DUCT CONNECTION. TRANSITION TO SUPPLY PLENUM OPENING SIZE. TYPICAL FOR 3.
- 8" DIA. DUCT DOWN TO AC PSP DUCT CONNECTION. TRANSITION TO SUPPLY PLENUM OPENING SIZE. TYPICAL. CAP UNUSED DUCT CONNECTIONS.
- INSTALL SINGLE GANGE VERTICAL J-BOX GRIDPOINT THERMOSTATS FURNISHED BY TEMS FOR RTU-1 AND RTU-2 AT THIS LOCATION AT 48" AFF. COORDINATE WITH ELECTRICAL SWITCHING IN THIS AREA. PROVIDE WIRING AS SHOWN IN DETAIL 8/E710.
- INSTALL GRIDPOINT ZONE SENSOR MODULE FURNISHED BY TEMS FOR RTU-1 AT THIS LOCATION 60" AFF DIRECTLY TO WALL (NO JUNCTION BOX). COORDINATE LOCATION WITH EQUIPMENT. PROVIDE WIRING AS SHOWN IN DETAIL 8/E710.
- INSTALL GRIDPOINT ZONE SENSOR MODULE FURNISHED BY TEMS FOR RTU-2 AT THIS LOCATION 66" AFF DIRECTLY TO WALL (NO JUNCTION BOX). COORDINATE LOCATION WITH EQUIPMENT. PROVIDE WIRING AS SHOWN IN DETAIL 8/E710.
- INSTALL GRIDPOINT SUPPLY PROBE FURNISHED BY TEMS FOR RTU-1 IN THE SUPPLY DUCTWORK UPSTREAM FROM THE FIRST BRANCH CONNECTION. PROVIDE WIRING AS SHOWN IN DETAIL 8/E710.
- INSTALL GRIDPOINT SUPPLY PROBE FURNISHED BY TEMS FOR RTU-2 IN THE SUPPLY DUCTWORK UPSTREAM FROM THE FIRST BRANCH CONNECTION. PROVIDE WIRING AS SHOWN IN DETAIL 8/E710.
- INSTALL REMOTE TEMPERATURE SENSOR FOR HOOD HD-1 AT THIS LOCATION 60" AFF. COORDINATE LOCATION WITH EQUIPMENT. PROVIDE (2) #18 G. THERMISTOR CABLE FROM TEMPERATURE SENSOR TO HOOD CONTROL PANEL.
- INSTALL KITCHEN HOOD, HD-1. SUPPORT HOOD PER MANUFACTURER'S INSTALLATION INSTRUCTIONS AND AS DETAILED IN THE ARCHITECTURAL AND STRUCTURAL DRAWINGS. INSTALL HOOD ACCORDING TO THE REQUIREMENTS OF ITS LISTING, IN COMPLIANCE WITH NFPA 96, THE BUILDING CODE, AND AUTHORITIES HAVING JURISDICTION. HOOD SHALL HAVE AN INTEGRAL DUCT COLLAR TEMPERATURE SENSOR TO AUTOMATICALLY ENERGIZE THE EXHAUST AND MAKEUP AIR FANS IF COOKING TEMPERATURES ARE DETECTED. EXHAUST DUCT SYSTEM TO BE WELDED OR FACTORY-MANUFACTURED WATER AND AIR TIGHT. INSTALL CLEANOUTS PER CODE AND AS SHOWN. INSTALL HOOD PER DETAILS 2, 4, AND 9/M700. CHIPOTLE WILL PROVIDE AN INDEPENDENT TESTING AGENCY FOR TESTING THE INTEGRITY OF THE GREASE DUCT SYSTEM.
- INSTALL REMOTE CONDENSING UNIT FOR WALK-IN COOLER ON ROOF AS DETAILED IN THE ARCHITECTURAL AND STRUCTURAL DRAWINGS. INSTALL REFRIGERANT LINE SET, THERMOSTATIC EXPANSION VALVE, SOLENOID VALVE, TEMPERATURE CONTROL, SIGHT GLASS, FILTER DRIER, PRESSURE CONTROL, LOW AMBIENT CONTROLS, AND WEATHERPROOF HOUSING. TRAP AND SLOPE REFRIGERANT LINES PER MANUFACTURER'S RECOMMENDATIONS. INSTALLATION SHALL COMPLY WITH ASHRAE/ANSI STANDARD 15. INSTALL THE REFRIGERANT LINE SET UNDER THE ROOF DECK TO WITHIN 3' OF THE CONDENSING UNIT. CUT 2-1/2" HOLE IN WALK-IN COOLER ROOF FOR REFRIGERANT LINE SET AND SEAL PER THE COOLER MANUFACTURER'S INSTALLATION INSTRUCTIONS AFTER LINE SET IS INSTALLED.
- INSTALL REMOTE CONDENSER FOR ICE MACHINE ON ROOF AS DETAILED IN THE ARCHITECTURAL AND STRUCTURAL DRAWINGS. INSTALL REFRIGERANT LINE SET, THERMOSTATIC EXPANSION VALVE, SOLENOID VALVE, TEMPERATURE CONTROL, SIGHT GLASS, FILTER DRIER, PRESSURE CONTROL, LOW AMBIENT CONTROLS, AND WEATHERPROOF HOUSING. TRAP AND SLOPE REFRIGERANT LINES PER MANUFACTURER'S RECOMMENDATIONS. SEAL PIPING PENETRATIONS THROUGH ROOF. INSTALLATION SHALL COMPLY WITH ASHRAE/ANSI STANDARD 15. INSTALL THE REFRIGERANT LINE SET UNDER THE ROOF DECK TO WITHIN 3' OF THE REMOTE CONDENSER. IF REFRIGERANT PIPING TO ICE MAKER IS EXPOSED TO PUBLIC VIEW CONCEAL WITHIN A STAINLESS STEEL SHROUD AS SHOWN IN THE ARCHITECTURAL DRAWINGS.
- INSTALL ROOFTOP EQUIPMENT PER MANUFACTURER'S INSTALLATION INSTRUCTIONS AND AS DETAILED IN THE ARCHITECTURAL AND STRUCTURAL DRAWINGS.
- INSTALL EXHAUST FAN EF-1 PER DETAIL 5/M700 AND AS DETAILED IN THE ARCHITECTURAL AND STRUCTURAL DRAWINGS. INSTALL GREASE VIROGUARD SYSTEM FURNISHED BY CHIPOTLE ON EXHAUST FAN, EF-1.
- PROVIDE SUPPLY DIFFUSER CONNECTION TO SUPPLY SYSTEM PER DETAIL 1/M700. TYPICAL.
- PROVIDE AUDIO/VISUAL REMOTE SMOKE DETECTOR ANNUNCIATOR WITH REMOTE KEY OPERATED RESET. WIRE A UNIT BACK TO EACH SMOKE DETECTOR. MOUNT UNIT 60" AFF. TYPICAL.
- INSTALL REME HALO AIR PURIFIER FURNISHED BY TUV IN RTU PER DETAIL 6/M700. SEE ELECTRICAL DRAWINGS FOR POWER CONNECTION INFORMATION. INSTALL UV WARNING STICKERS ON FACE OF ENCLOSURE PER DETAIL AND ON ANY RTU ACCESS DOOR(S) THROUGH WHICH THE REME HALO WOULD BE VISIBLE IF OPENED.
- MAINTAIN 10" CLEARANCE BETWEEN WATER HEATER FLUE TERMINATION AND OUTSIDE AIR INTAKES. MAINTAIN 10" CLEARANCE BETWEEN WATER HEATER COMBUSTION AIR INTAKE AND EXHAUST FAN EF-1 DISCHARGE. SEE PLUMBING DRAWINGS FOR MORE INFORMATION ON WATER HEATER FLUE AND COMBUSTION AIR TERMINATIONS.
- PENETRATIONS THROUGH SHEAR WALL SHALL BE LIMITED TO 10" DIAMETER (OR A GROUP OF PENETRATIONS ALL CONTAINED WITHIN 10" DIAMETER). IF LARGER PENETRATIONS OR GROUPS OF PENETRATIONS ARE REQUIRED COORDINATE WITH STRUCTURAL ENGINEER FOR APPROPRIATE BRACING. SEE ARCHITECTURAL DRAWINGS FOR SHEAR WALL LOCATION.

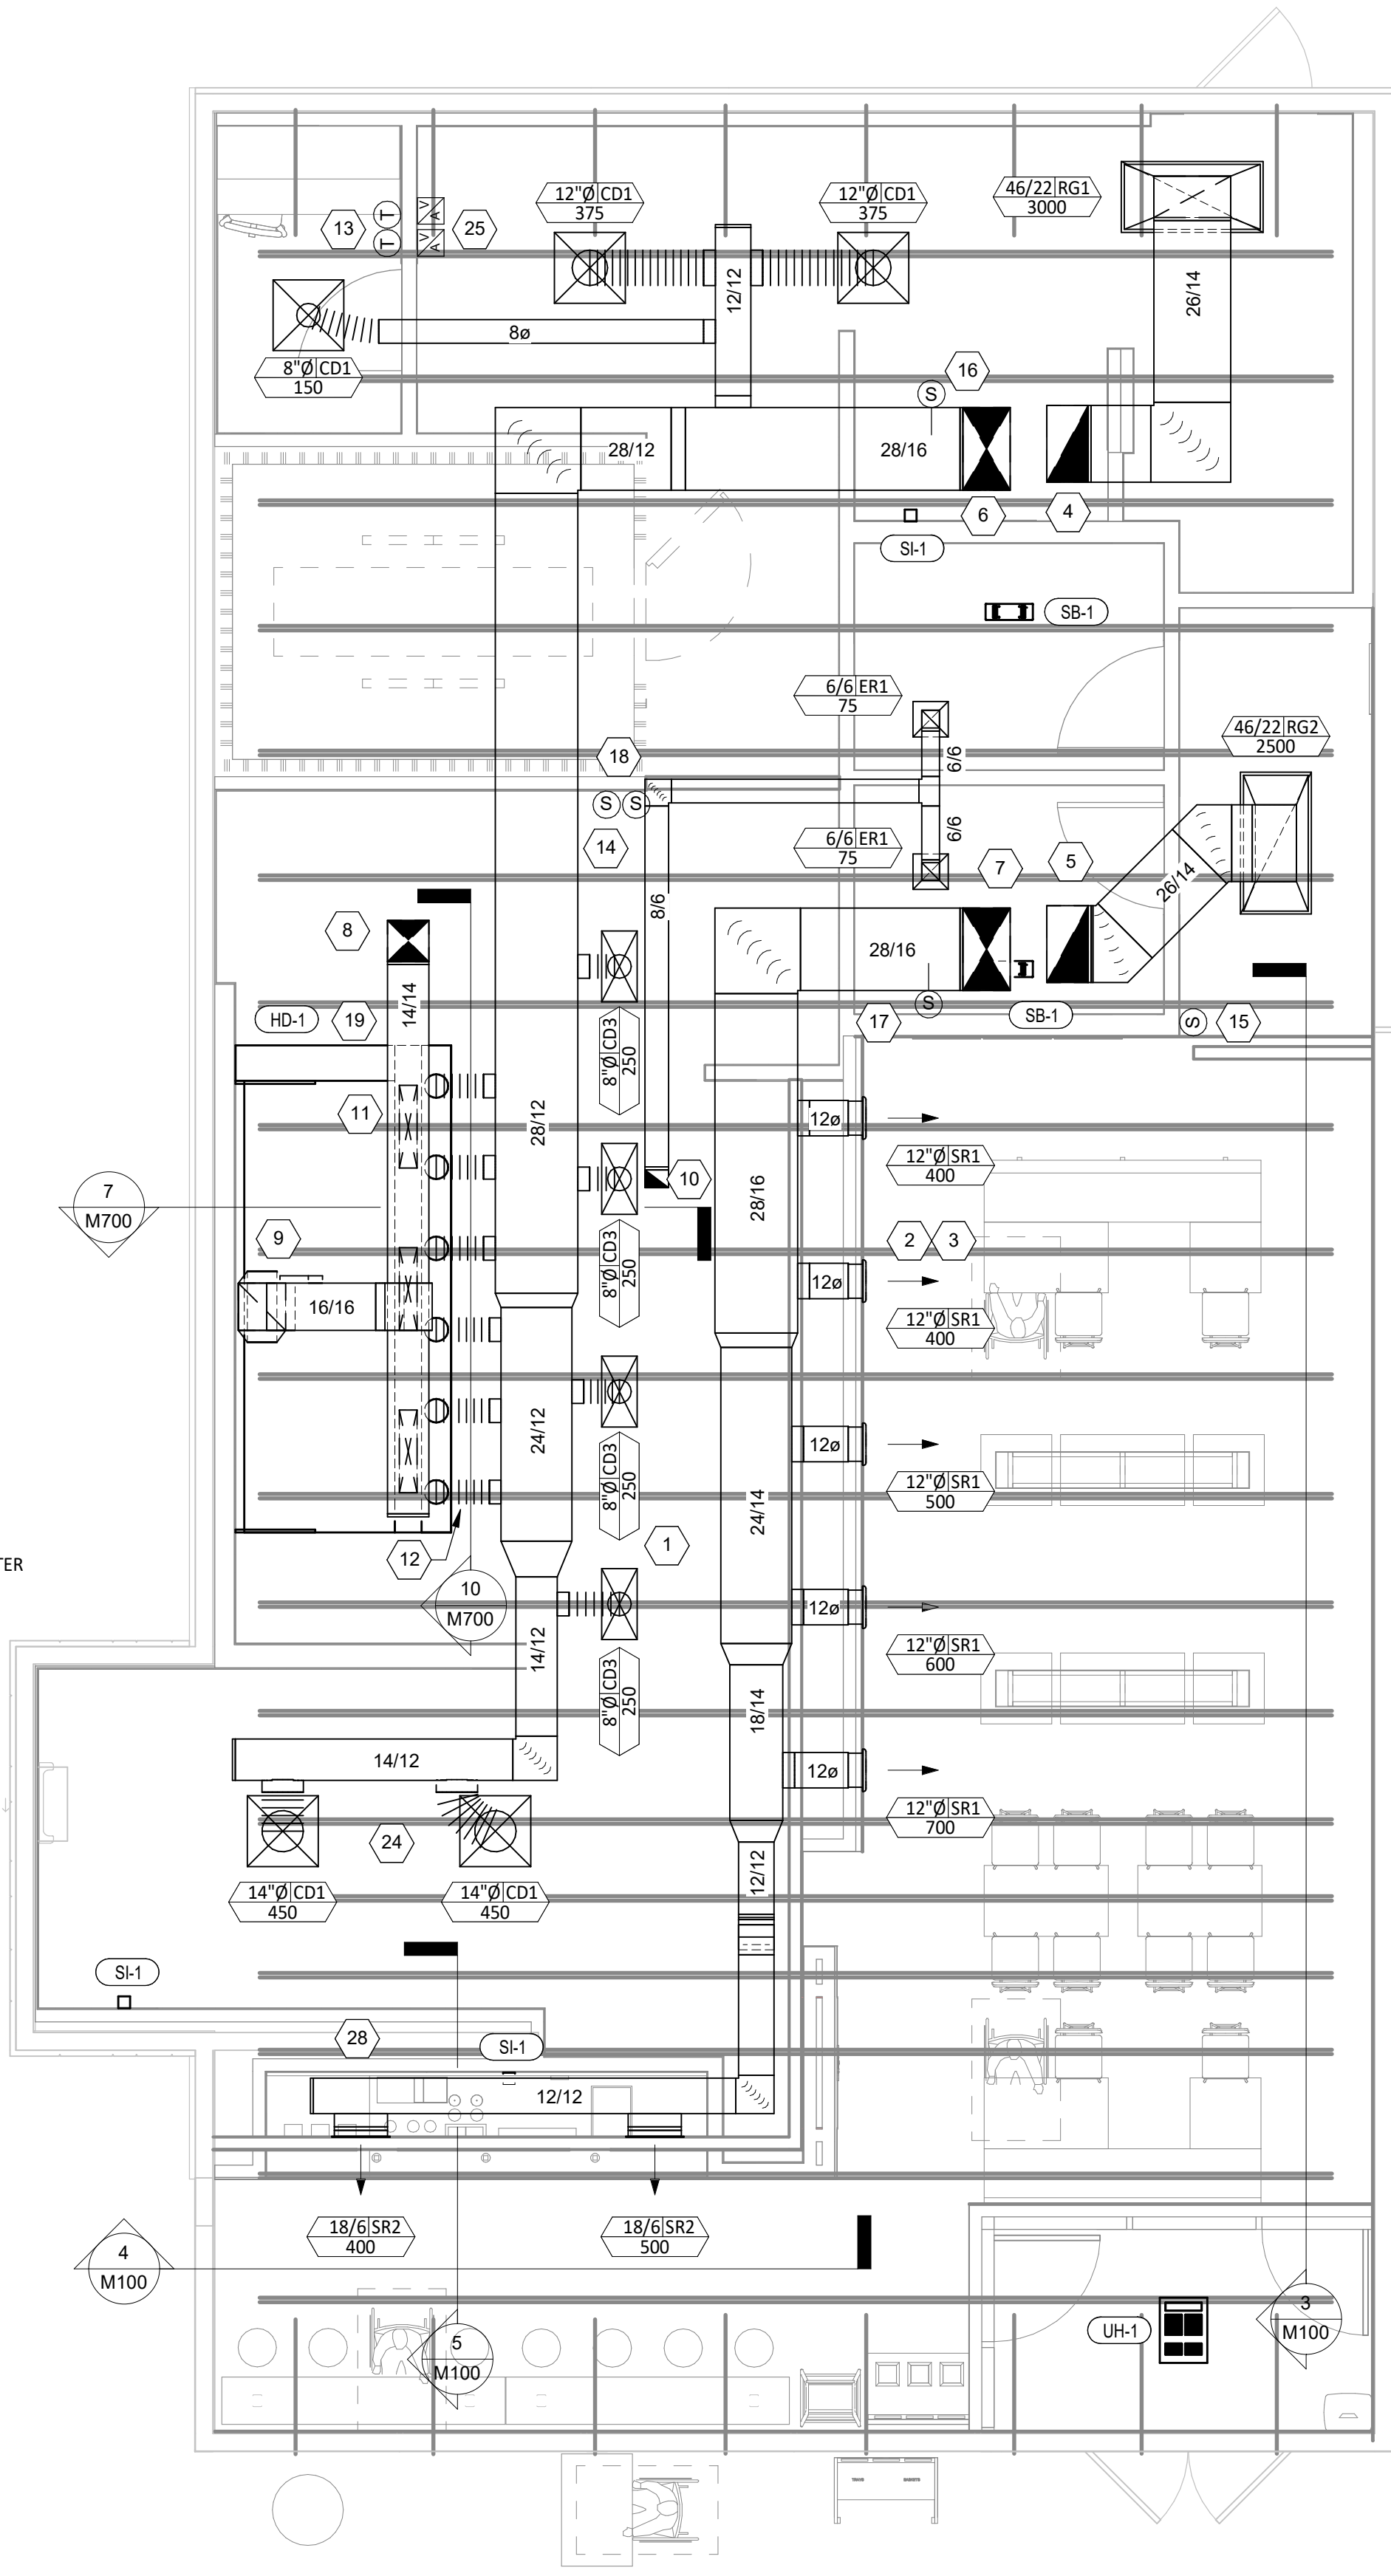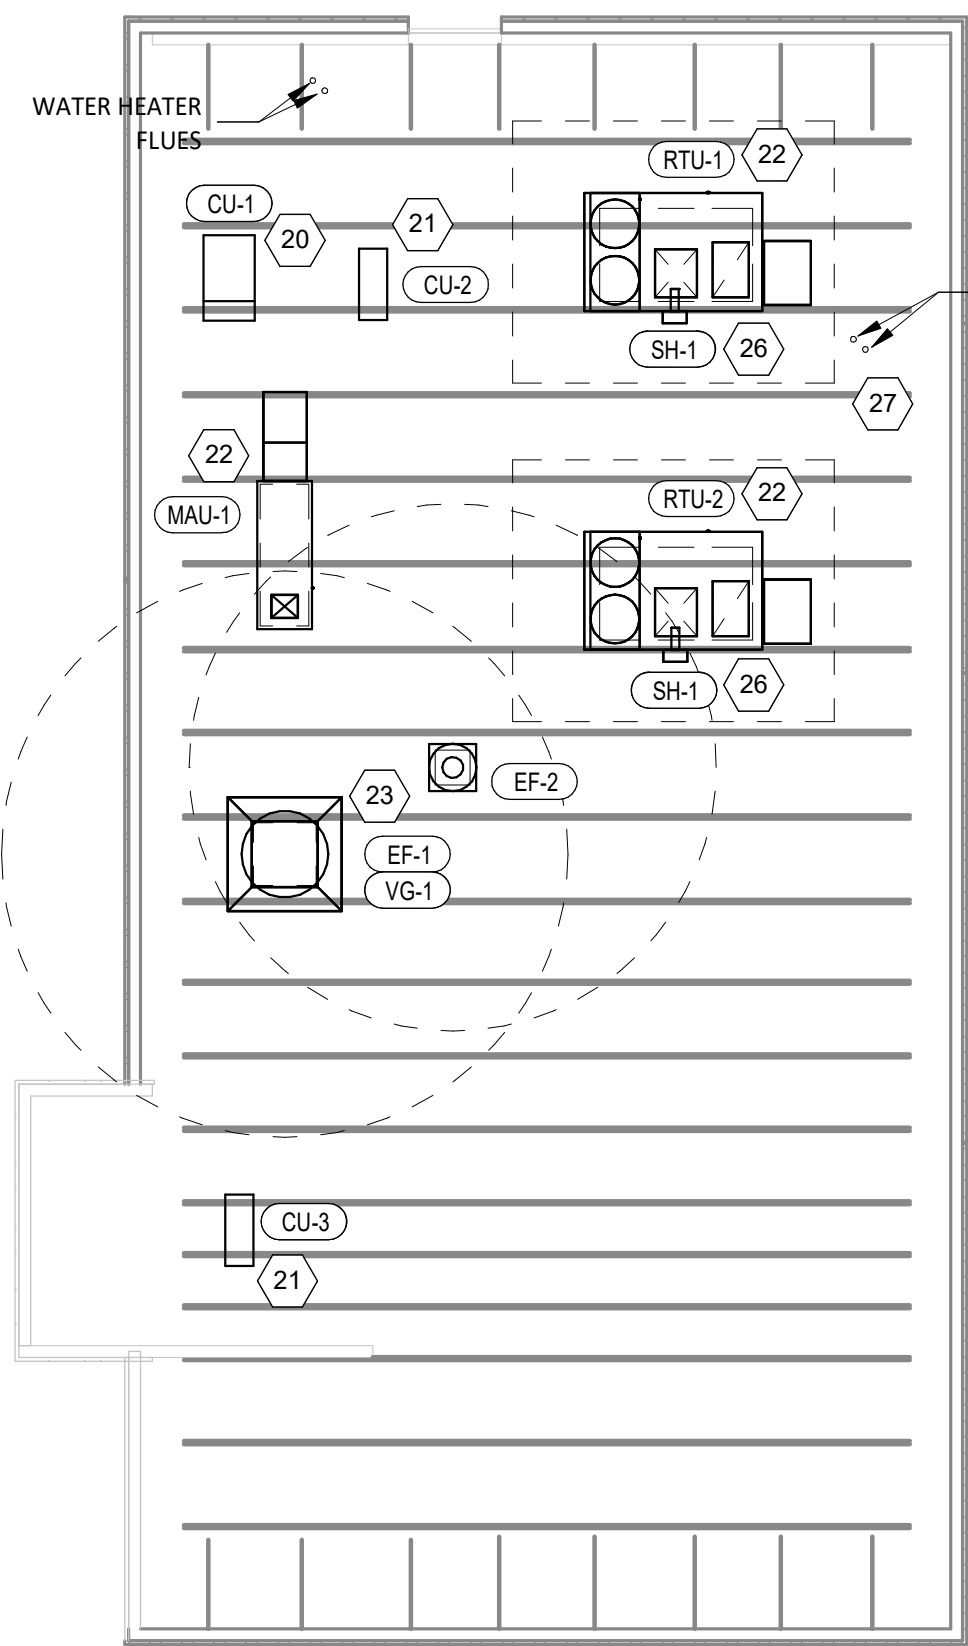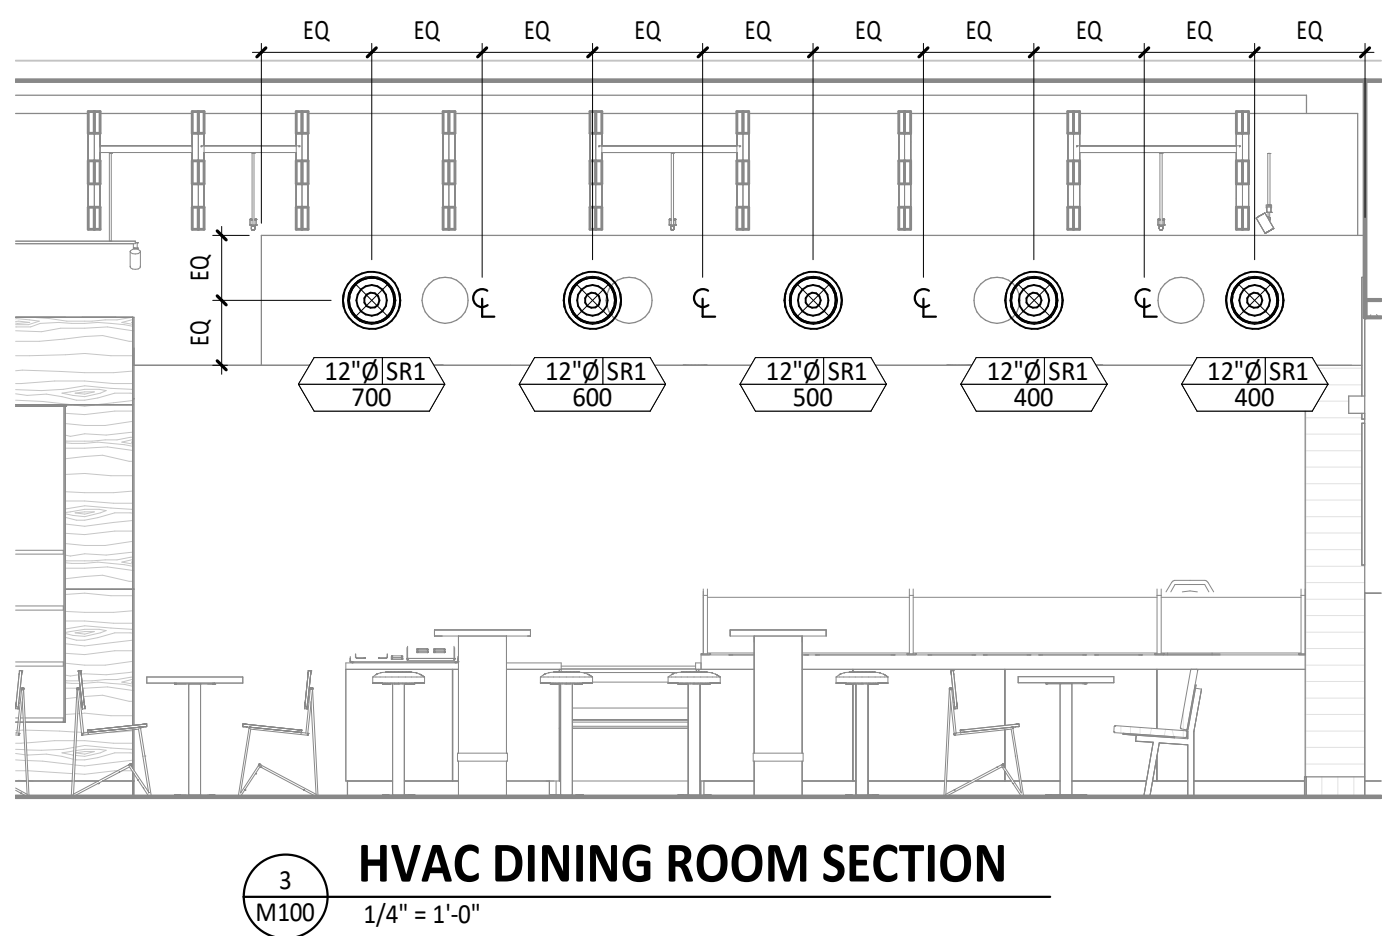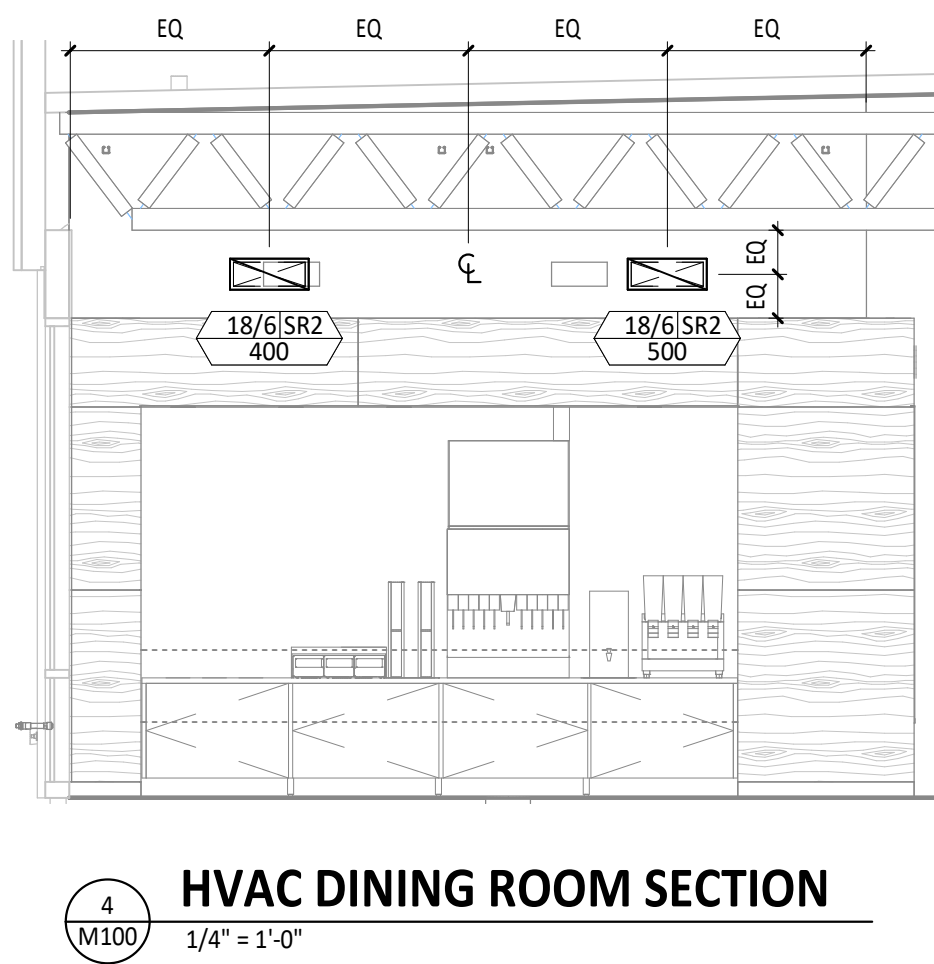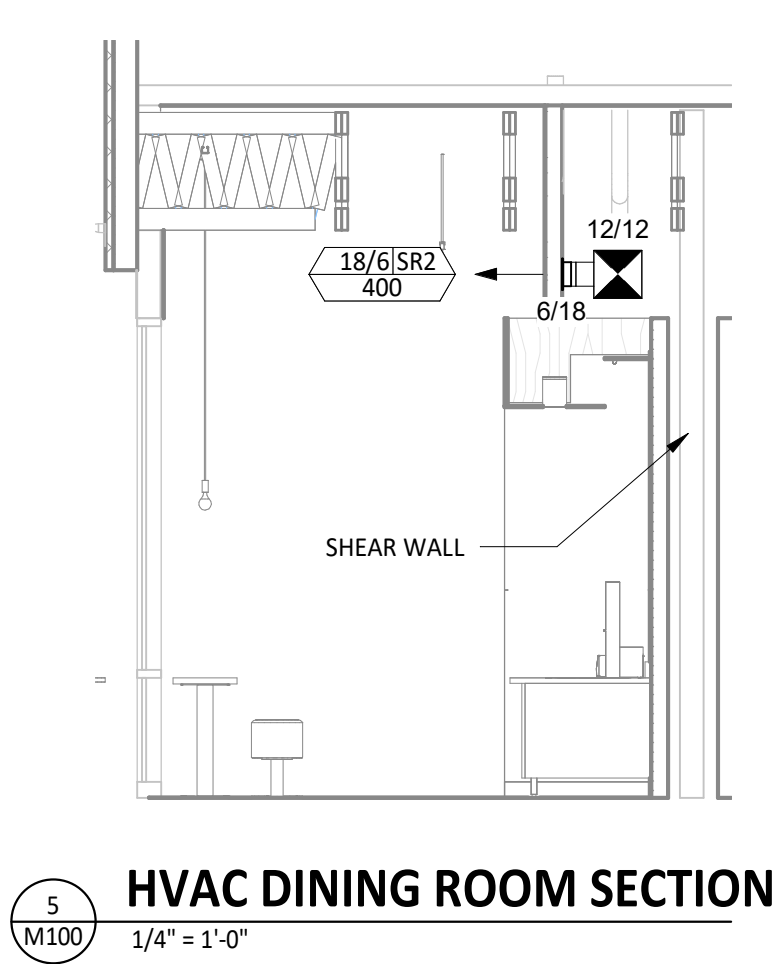

Consultant:

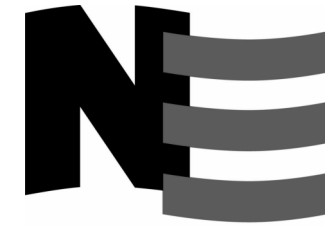

4635 Trueman Blvd. Suite 250
Hilliard, Ohio 43026
Phone: (614) 751-9610
Fax: (614) 552-5240
Contact: Cliff Kigar
(614) 328-2033
ckigar@nationalengineering.com

FOR CONSTRUCTION

COPYRIGHT 2024
THIS DRAWING IS AN INSTRUMENT OF SERVICE
AND AS SUCH REMAINS THE PROPERTY OF
CHIPOTLE MEXICAN GRILL, INC.. PERMISSION FOR
USE OF THIS DOCUMENT IS LIMITED AND CAN BE
EXTENDED ONLY BY WRITTEN AGREEMENT WITH
CHIPOTLE MEXICAN GRILL, INC..



CHIPOTLE MEXICAN GRILL, INC.
PO BOX 182566
COLUMBUS, OH 43218-2566
TELEPHONE: (614) 318-2400
INTERNET: WWW.CHIPOTLE.COM

STORE NO.: 4757
ANDERSON
S SCATTERFIELD RD
ANDERSON, IN 46013

Issue Record:
12/12/2023 PERMIT SET
05/20/2024 BID SET
07/24/2024 CONSTRUCTION SET

Revisions:

Drawn: CJK
Checked: JEJ

Project No.
2201198

Contents:

HVAC PLAN

M100

SANITIZING EQUIPMENT SCHEDULE

TAG	COUNT	DESCRIPTION	FURNISH ED BY	INSTALLE D BY	BASIS FOR DESIGN		REMARKS
					MANUFACTURER	MODEL	
SB-1	2	BATHROOM AIR PURIFICATION UNIT	TUV	GC	RGF ENVIRONMENTAL GROUP	BRU ASSEMBLY	SEE ELECTRICAL SHEETS FOR CONNECTING INFORMATION.
SH-1	2	HVAC AIR PURIFICATION UNIT	TUV	GC	RGF ENVIRONMENTAL GROUP	REME-HALO	SEE DETAIL G/700 FOR INSTALLATION INFORMATION.
SI-1	3	ICE MACHINE TREATMENT SYSTEM	TUV	GC	RGF ENVIRONMENTAL GROUP	IMS-B-GA	SEE PLUMBING DRAWINGS FOR INSTALLATION INFORMATION.

VIROGUARD SCHEDULE

TAG	QUANTITY	DESCRIPTION	DUCT CONNECTION SIZE	FAN	FURNISHED BY	INSTALLED BY	BASIS FOR DESIGN MANUFACTURER
VG-1	1	VIROGUARD HOOD EXHAUST FAN ROOFTOP CONTAINMENT SYSTEM	16" X 16"	CAPTIVE-AIRE DU180HFA	TDC	GC	ENVIROMATIC

UNIT HEATER SCHEDULE

TAG	DESCRIPTION	MOUNTING	ELECTRICAL		FURNISHED	INSTALLED	BASIS FOR DESIGN		REMARKS
			POWER	V/P/H	BY	BY	MANUFACTURER	MODEL	
UH-1	CEILING-MOUNTED UNIT HEATER	CEILING	3 KW	208/1/60	GC	GC	INDEECO	931U0400V	

GRILLS, REGISTERS, AND DIFFUSERS SCHEDULE

TAG	DESCRIPTION	FACE SIZE	MATERIAL	FINISH	MOUNTING	FURNISHED BY	INSTALLED BY	BASIS FOR DESIGN		NOTES
								MANUFACTURER	MODEL	
CD1	PERFORATED CEILING DIFFUSER	24" X 24"	ALUMINUM	WHITE	LAY-IN CEILING	GC	GC	NAILOR	4320A TYPE L	PROVIDE INTEGRAL OBD
CD3	PERFORATED CEILING DIFFUSER	24" X 12"	ALUMINUM	WHITE	LAY-IN CEILING	GC	GC	NAILOR	4320A TYPE L	PROVIDE INTEGRAL OBD, REMOVE 4-WAY DEFLECTOR
ER1	PERFORATED CEILING EXHAUST	12" X 12"	ALUMINUM	WHITE	GYP CEILING	GC	GC	NAILOR	4330R TYPE S	PROVIDE INTEGRAL OBD
RG1	PERFORATED CEILING RETURN	48" X 24"	ALUMINUM	WHITE	LAY-IN CEILING	GC	GC	NAILOR	4330R TYPE L	
RG2	PERFORATED CEILING RETURN	48" X 24"	ALUMINUM	WHITE	GYP CEILING	GC	GC	NAILOR	4330R TYPE S	
SR1	ADJUSTABLE TURBO NOZZLE	SEE NECK SIZE	ALUMINUM	WHITE	WALL	GC	GC	AIR CONCEPTS	ANR-12	PROVIDE FACE-ACCESSIBLE OBD
SR2	DOUBLE DEFLECTION SUPPLY REGISTER	SEE NECK SIZE	ALUMINUM	WHITE	WALL	GC	GC	NAILOR	51DH	PROVIDE INTEGRAL OBD

FAN SCHEDULE

TAG	DRIVE TYPE	EXHAUST FLOW [CFM]	E.S.P. [in W.C.]	WEIGHT [lbs]	ELECTRICAL		FURNISHED BY	INSTALLED BY	BASIS FOR DESIGN		REMARKS
					MOTOR POWER	V/P/H			MANUFACTURER	MODEL	
EF-1	DIRECT	2550 CFM	1.20 in-wg	400	2	208/3/60	HS	GC	CAPTIVE-AIRE	DU180HFA	FURNISHED WITH DISCONNECT AND VENTED ROOF CURB
EF-2	DIRECT	150 CFM	0.60 in-wg	100	0.18 HP	120/1/60	HS	GC	CAPTIVE-AIRE	DR12HFA	FURNISHED WITH DISCONNECT, VARIABLE SPEED CONTROLLER, BACKDRAFT DAMPER AND ROOF CURB

MAKEUP AIR UNIT SCHEDULE

TAG	DESCRIPTION	AIRFLOW		HEATING CAPACITY				APPROXIMATE WEIGHT [lbs]	ELECTRICAL		FURNISHED BY	INSTALLED BY	BASIS FOR DESIGN		REMARKS
		SUPPLY FLOW [CFM]	E.S.P. [in. W.C.]	INPUT [MBH]	OUTPUT [MBH]	MAXIMUM TURNDOWN	EAT		MOTOR POWER	V/P/H			MANUFACTURER	MODEL	
MAU-1	MAKEUP AIR UNIT	1300	0.80	225	220	12.5:1	7 °F	650	1 HP	208/3/60	HS	GC	CAPTIVE-AIRE	A1-D.250-15D	FURNISHED WITH DISCONNECT, ROOF CURB, SCREEN INTAKE, AND WASHABLE ALUMINUM FILTERS

CONDENSING UNIT SCHEDULE

TAG	DESCRIPTION	NOMINAL CAPACITY [TONS]	NUMBER OF COMPRESSORS	NUMBER OF CIRCUITS	REFRIGERANT TYPE	REFRIGERANT CHARGE	WEIGHT	ELECTRICAL			FURNISHED BY	INSTALLED BY	BASIS FOR DESIGN		REMARKS
								MOCP	FLA	V/P/H			MANUFACTURER	MODEL	
CU-1	WALK-IN COOLER REMOTE CONDENSING UNIT	--	1	1	R-448A	9.9	200	15 A	7.2 A	208/3/60	WCS	GC	EVERIDGE	RFO130E4SEA	FURNISHED WITH WALK-IN COOLER
CU-2	ICE MAKER - REMOTE CONDENSER	--	0	1	R-404A	11 lbs 7.4 oz	100			120/1/60	KES	GC	-	-	FURNISHED WITH ICE MAKER
CU-3	ICE MAKER - REMOTE CONDENSER	--	0	1	R-404A	11 lbs 7.4 oz	100			120/1/60	KES	GC	-	-	FURNISHED WITH ICE MAKER

KITCHEN HOOD SCHEDULE

TAG	DESCRIPTION	MAX COOKING TEMP.	EXHAUST PLENUM							PERFORATED SUPPLY PLENUMS									NUMBER OF LIGHT FIXTURES	APPROXIMATE WEIGHT [lbs]	FURNISHED BY	INSTALLED BY	BASIS FOR DESIGN		REMARKS	
			AIRFLOW [CFM]	SP [in. W.C.]	DUCT COLLARS			LENGTH	WIDTH	SP [in. W.C.]	SUPPLY PLENUM LENGTH	SUPPLY PLENUM WIDTH	MAU PLENUM			AC PLENUM										
					NO.	WIDTH	LENGTH						AIRFLOW [CFM]	DUCT COLLARS												
														NO.	DIAMETER											
HD-1	TYPE I CANOPY HOOD WITH PERFORATED MAU AND AC SUPPLY PLENUMS	600°F	2550	0.97	1	10"	24"	12' - 9"	4' - 3"	0.1	13' - 9"	19"	1300	3	6"	28"	700	6	8"	8	1100	HS	GC	CAPTIVE-AIRE	5424 ND-2-ACPS-PF	MAT'L: 18 GA. TYPE 430 SS. PROVIDE WITH VERTICAL END PANELS, 16" TALL HE SS FILTERS, INTEGRAL UTILITY CABINET, KITCHEN EXHAUST SUPPRESSION SYSTEM, DUCT COLLAR TEMPERATURE SENSOR, PREWIRE PACKAGE, SPARE FIRE SYSTEM DRY CONTACT, AND 4-POLE 20A CONTACTOR

ROOFTOP UNIT SCHEDULE

TAG	DESCRIPTION	NOMINAL CAPACITY [TONS]	EER	AIRFLOW			NET COOLING CAPACITY					HEATING CAPACITY			# OF COMPRESSORS	# OF CIRCUITS	REFRIG. TYPE	REFRIG. CHARGE	APPROX. WEIGHT [lbs]	ELECTRICAL			FURNISHED BY	INSTALLED BY	BASIS FOR DESIGN		REMARKS
				TOTAL [CFM]	OA [CFM]	ESP [IN. W.C.]	TOTAL [MBH]	SENSIBLE [MBH]	DB	WB	COND. EAT [DEG. F]	INPUT [MBH]	OUTPUT [MBH]	EAT [DEG. F]						MOCP	FLA	V/P/H			MANUFACTURER	MODEL	
RTU-1	KITCHEN ROOFTOP UNIT	10	12	3500	500	0.8	120	75	76	66	90	240	192	59	2	2	R-410A	7.9/7.9	1350	30 A	24.2 A	460/3/60	HES	GC	YORK	Z1120	FURNISHED WITH COMP. ENTHALPY ECON., BAROMETRIC RELIEF, RET. SMOKE DETECTOR W/ REMOTE KEYED ANNUNCIATOR/RESET, M.O.D., MERV-8 FILTERS, CURB, HAIL GUARD, TOOLLESS HINGED ACCESS PANELS, DISCONNECT, & UNIT-MOUNTED CONVENIENCE RECEPTACLE
RTU-2	DINING ROOM ROOFTOP UNIT	10	12	3500	1000	0.8	124	74	78	68	90	240	192	50	2	2	R-410A	7.9/7.9	1350	30 A	24.2 A	460/3/60	HES	GC	YORK	Z1120	FURNISHED WITH COMP. ENTHALPY ECON., BAROMETRIC RELIEF, RET. SMOKE DETECTOR W/ REMOTE KEYED ANNUNCIATOR/RESET, M.O.D., MERV-8 FILTERS, CURB, HAIL GUARD, TOOLLESS HINGED ACCESS PANELS, DISCONNECT, & UNIT-MOUNTED CONVENIENCE RECEPTACLE

CONTROL FUNCTIONS

- A. THE MAIN COOKING EXHAUST FAN AND MAKE-UP AIR UNIT SHALL BE INTERLOCKED TO OPERATE TOGETHER. THIS CONTROL CIRCUIT IS ACTIVATED BY A SWITCH AND INCLUDES A FIRE PROTECTION OVERRIDE.
- B. THE TEMPERATURE IN EACH ZONE IS CONTROLLED BY SPACE TEMPERATURE SENSORS CONNECTED TO THE THERMOSTATS LOCATED IN THE OFFICE. ALL ZONES SHALL OPERATE WITH CONTINUOUS FAN OPERATION DURING OCCUPIED TIMES AND INTERMITTENTLY AS NEEDED TO MAINTAIN SET POINTS DURING UNOCCUPIED TIMES. OUTSIDE AIR DAMPERS SHALL BE OPEN CONTINUOUSLY WHEN EITHER IN OCCUPIED MODE OR WHEN THE HOOD SYSTEM IS ON AND SHALL BE CLOSED DURING UNOCCUPIED PERIODS.
- C. THE THERMOSTATS SHALL DETERMINE OCCUPIED/UNOCCUPIED STATUS BASED ON THE SCHEDULE IN THE ENERGY MANAGEMENT SYSTEM.

AIR BALANCE SCHEDULE

Tag	Supply Flow [CFM]	Return Flow [CFM]	Exhaust Flow [CFM]	Subtotal [CFM]
EF-1	0	0	2550	-2550
EF-2	0	0	150	-150
MAU-1	1300	0	0	1300
RTU-1	3500	3000	0	500
RTU-2	3500	2500	0	1000
Net Pressurization [CFM]				100

Consultant:



NATIONAL
ENGINEERING

4635 Trueman Blvd. Suite 250
Hilliard, Ohio 43026

Phone: (614) 751-9610
Fax: (614) 552-5240
Contact: Cliff Kigar
(614) 328-2033

ckigar@nationalengineering.com

FOR CONSTRUCTION

COPYRIGHT 2024
THIS DRAWING IS AN INSTRUMENT OF SERVICE
AND AS SUCH REMAINS THE PROPERTY OF
CHIPOTLE MEXICAN GRILL, INC.. PERMISSION FOR
USE OF THIS DOCUMENT IS LIMITED AND CAN BE
EXTENDED ONLY BY WRITTEN AGREEMENT WITH
CHIPOTLE MEXICAN GRILL, INC..



CHIPOTLE MEXICAN GRILL, INC.
PO BOX 182566
COLUMBUS, OH 43218-2566
TELEPHONE: (614) 318-2400
INTERNET: WWW.CHIPOTLE.COM

STORE NO.: 4757
ANDERSON
S SCATTERFIELD RD
ANDERSON, IN 46013

Issue Record:	
<u>12/12/2023</u>	PERMIT SET
<u>05/20/2024</u>	BID SET
<u>07/24/2024</u>	CONSTRUCTION SET

Revisions:
1 05-20-2024 RTU REVISION


Drawn:	Checked:
CJK	JEJ

Project No.
2201198


Contents:

HVAC SCHEDULES


M600

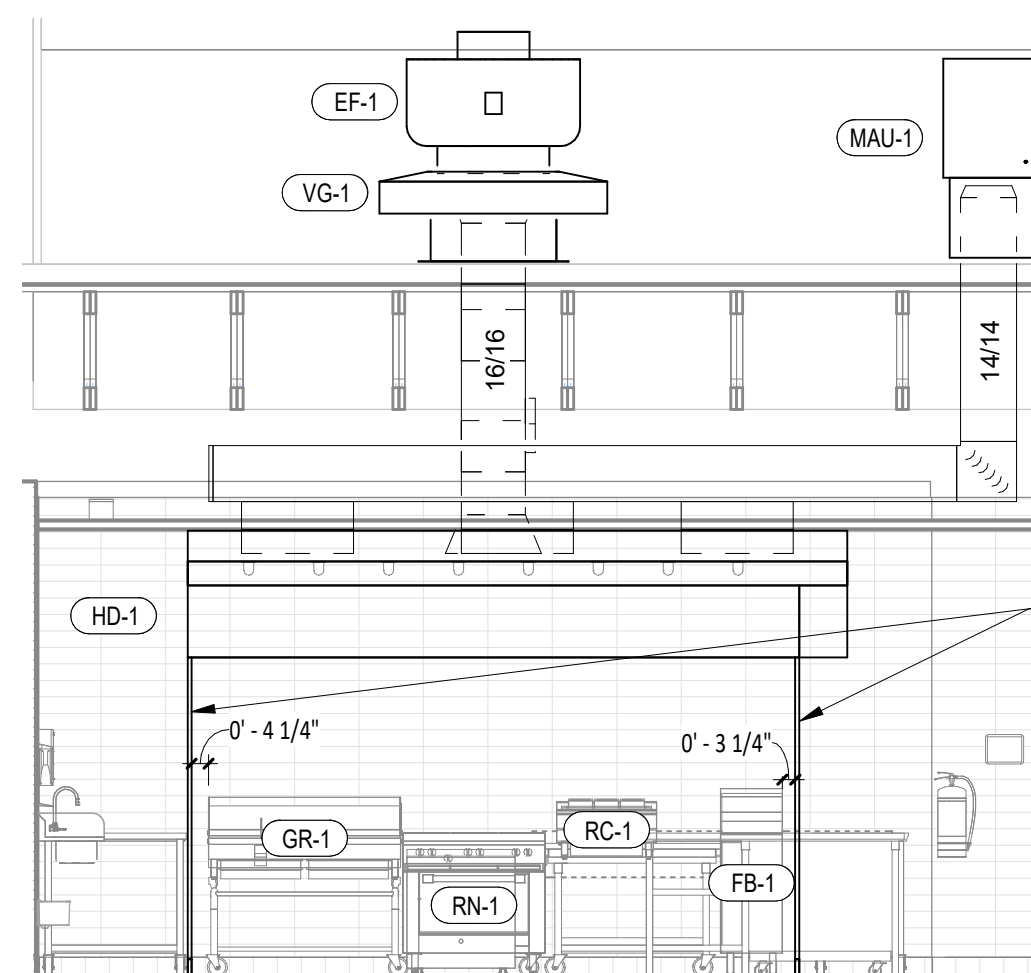

HOOD ELEVATION

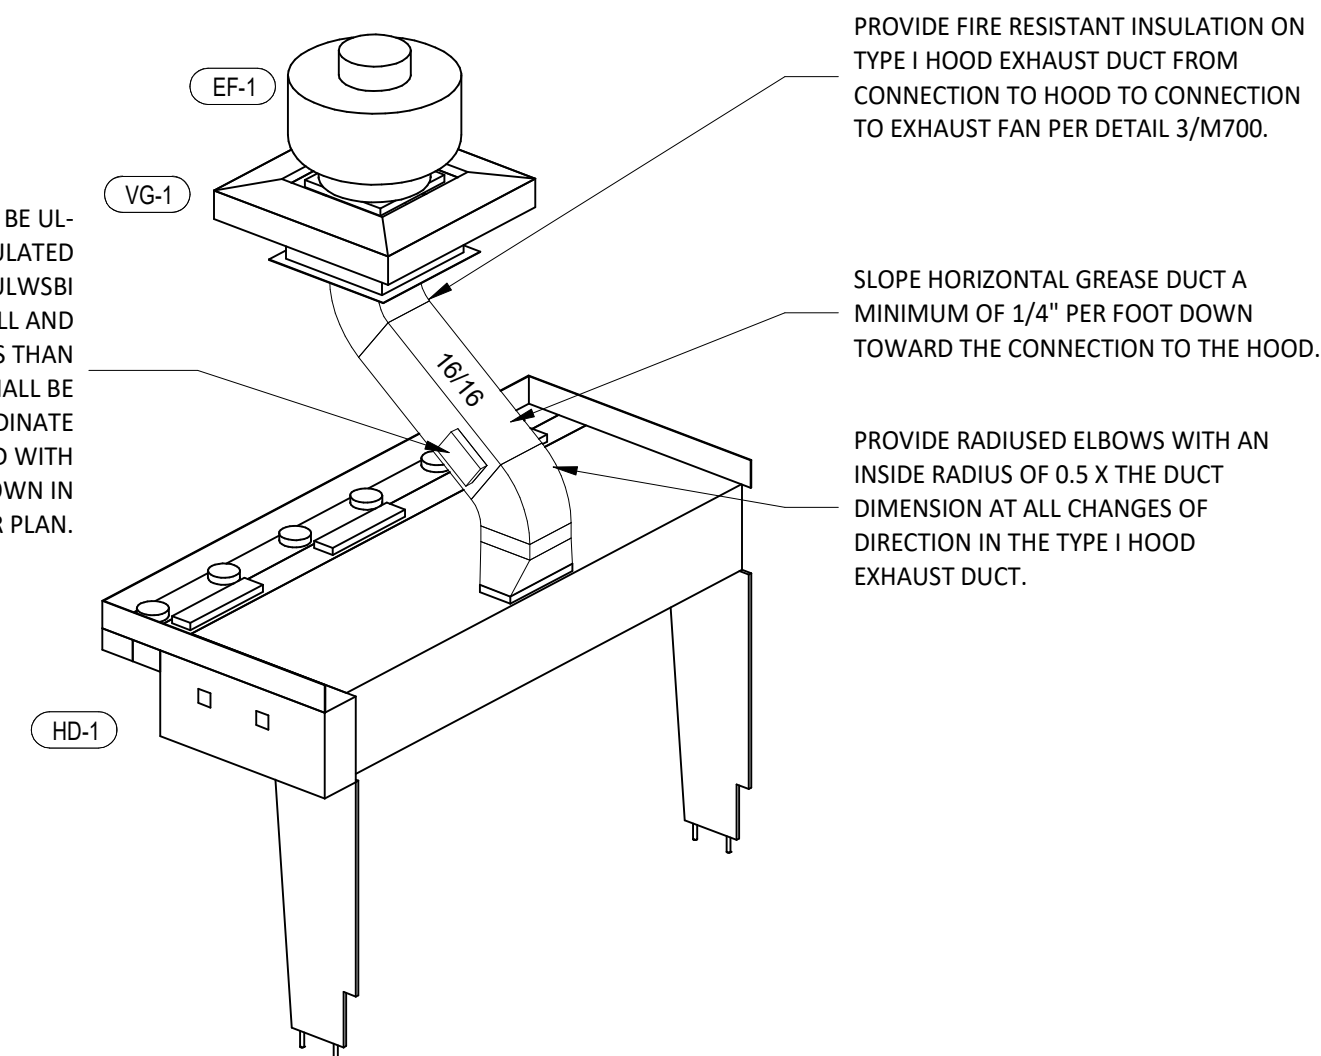


8 HOOD EXHAUST ISOMETRIC
M700 N.T.S.

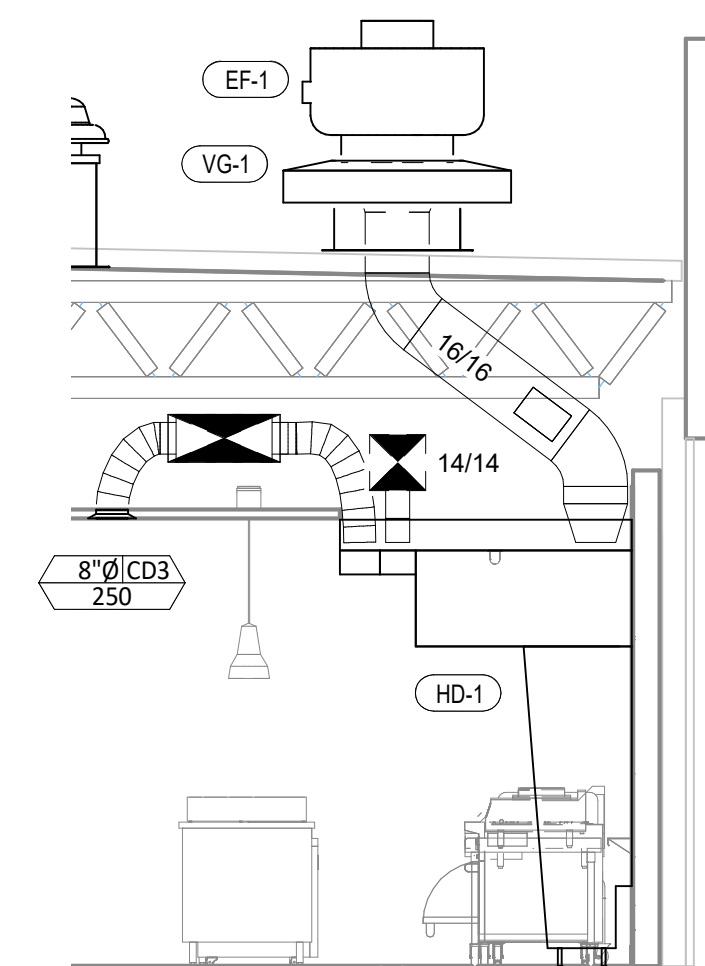

7
M700

DUCT SECTION AT HOOD

1/4" = 1'-0"

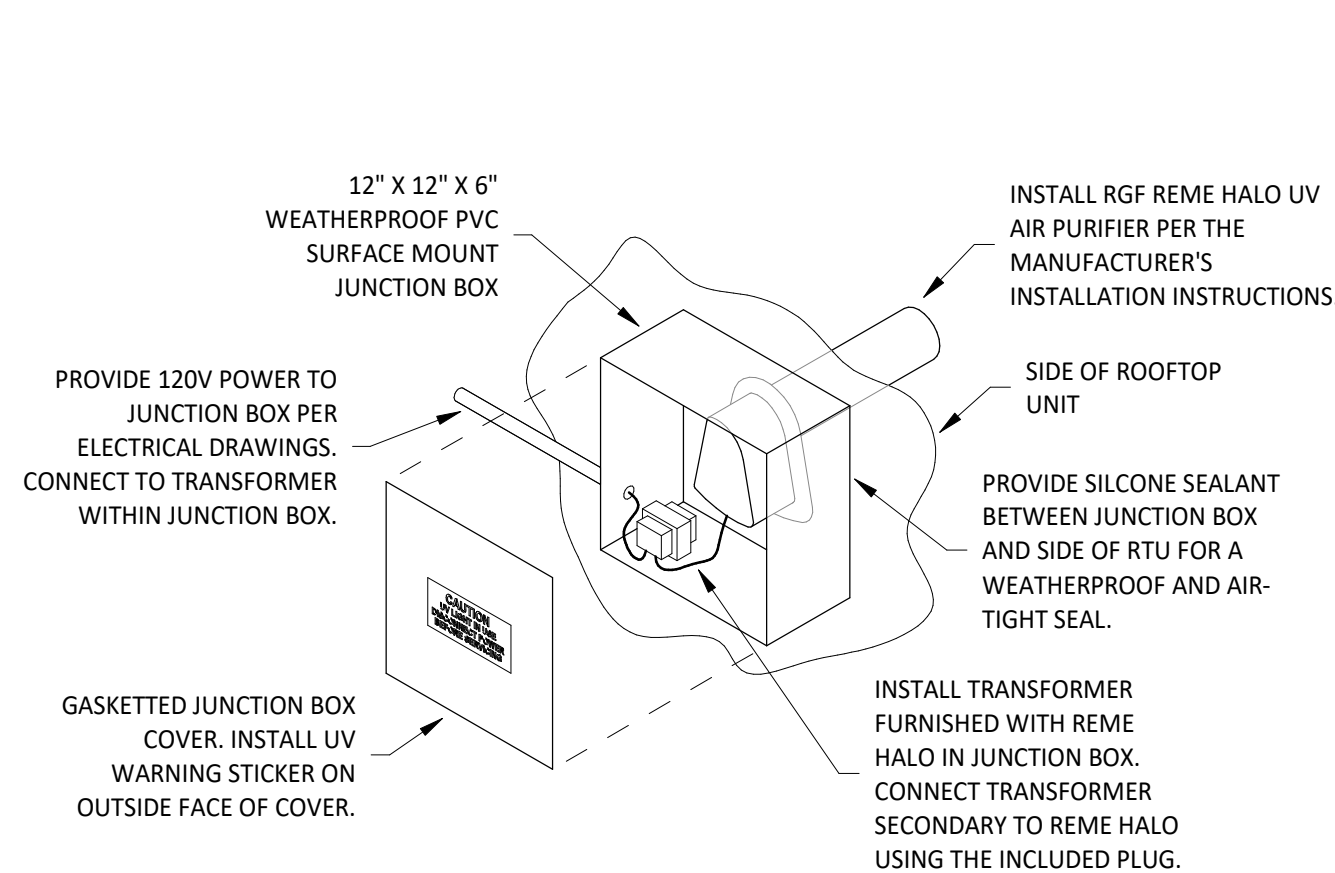

INSTALLATION LOCATION

INSTALL AIR PURIFIER WITH JUNCTION BOX ON OUTSIDE FACE OF ROOFTOP UNIT AND WITH UV LAMP TUBE EXTENDING INTO THE INTERIOR OF THE ROOFTOP UNIT. FIELD VERIFY EXACT LOCATION TO AVOID DAMAGING, TOUCHING, OR INTERFERING WITH ANY RTU INTERIOR COMPONENTS. INSTALLATION LOCATION SHALL BE AS FOLLOWS:


TRANE: INSTALL INTO THE SUPPLY AIR STREAM THROUGH THE REMOVABLE PANEL COVERING THE HORIZONTAL DISCHARGE SUPPLY AIR OPENING.

YORK: INSTALL INTO THE SUPPLY AIR PLENUM FROM THE BACK SIDE OF THE UNIT JUST ABOVE THE HEAT EXCHANGER.

6
M700

UV AIR PURIFIER INSTALLATION


N.T.S.

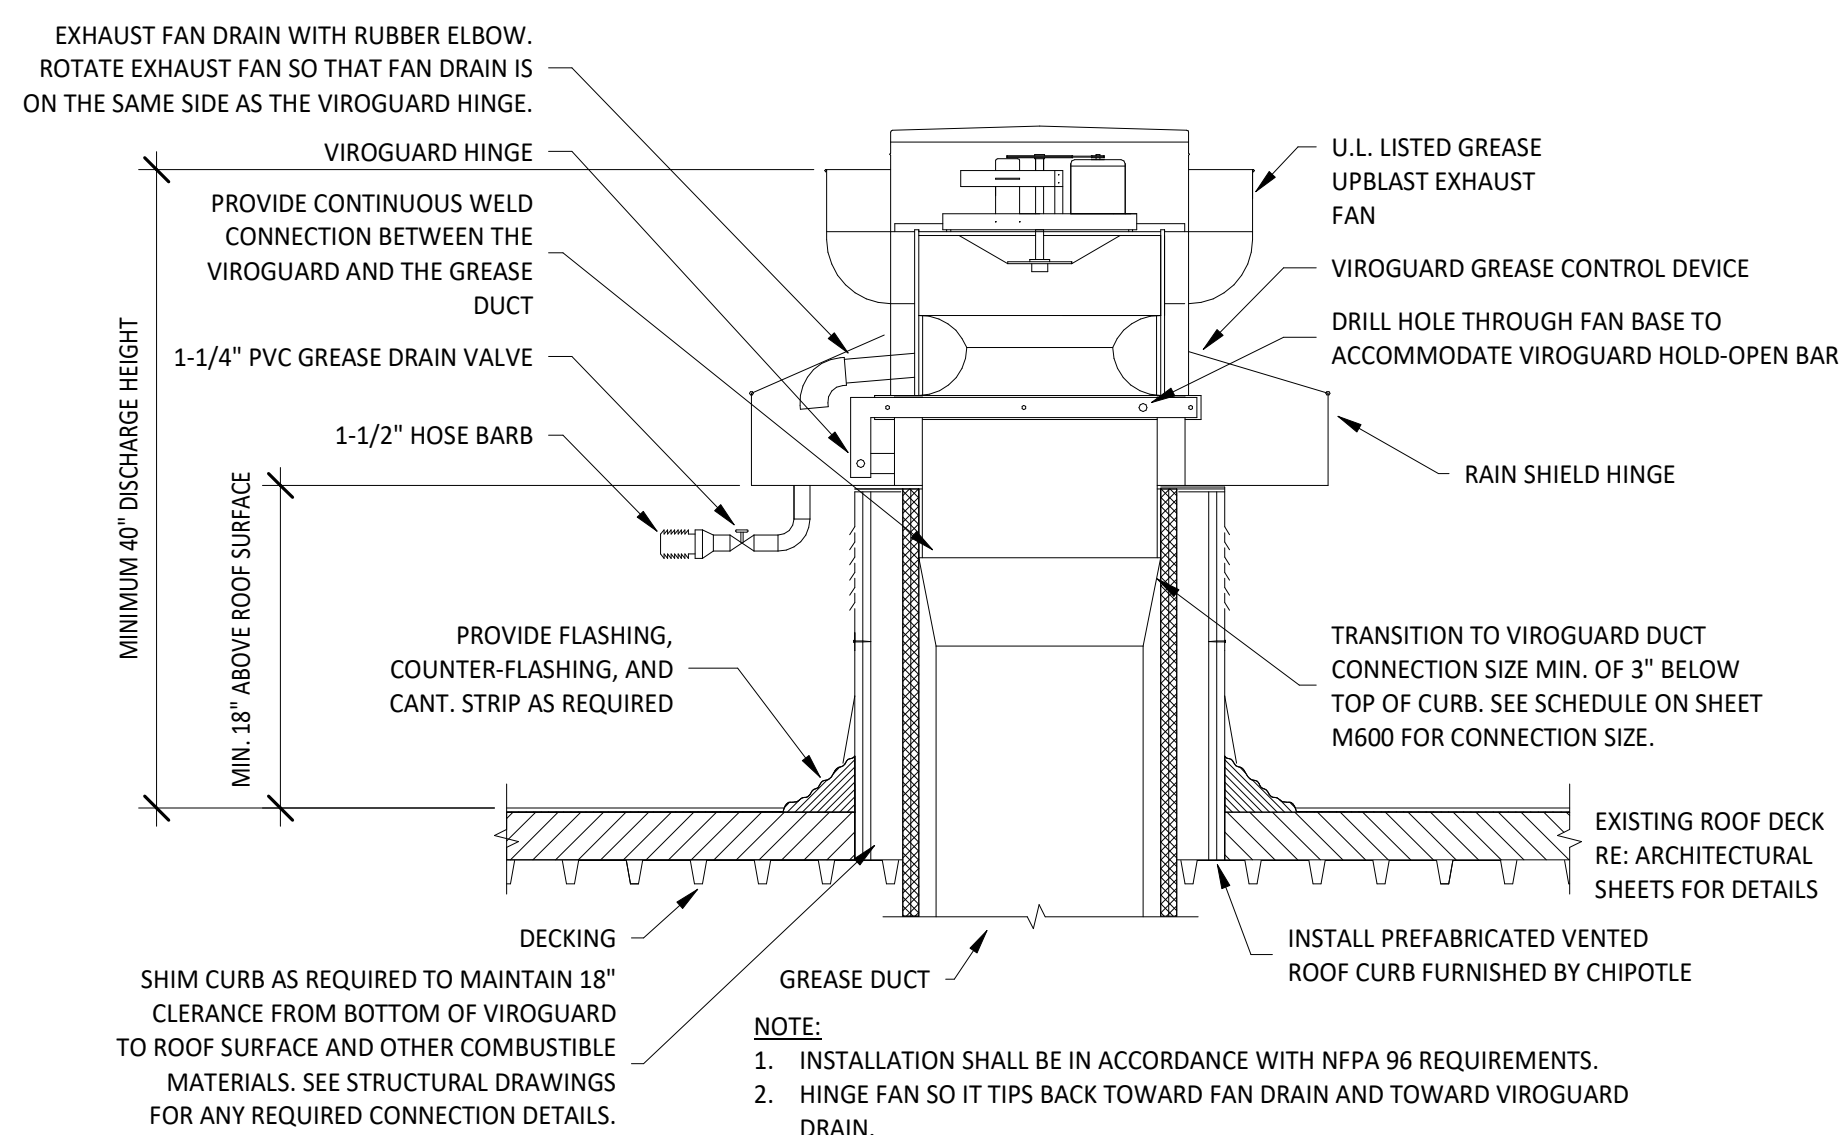

5
M700

GREASE EXHAUST FAN

N.T.S.

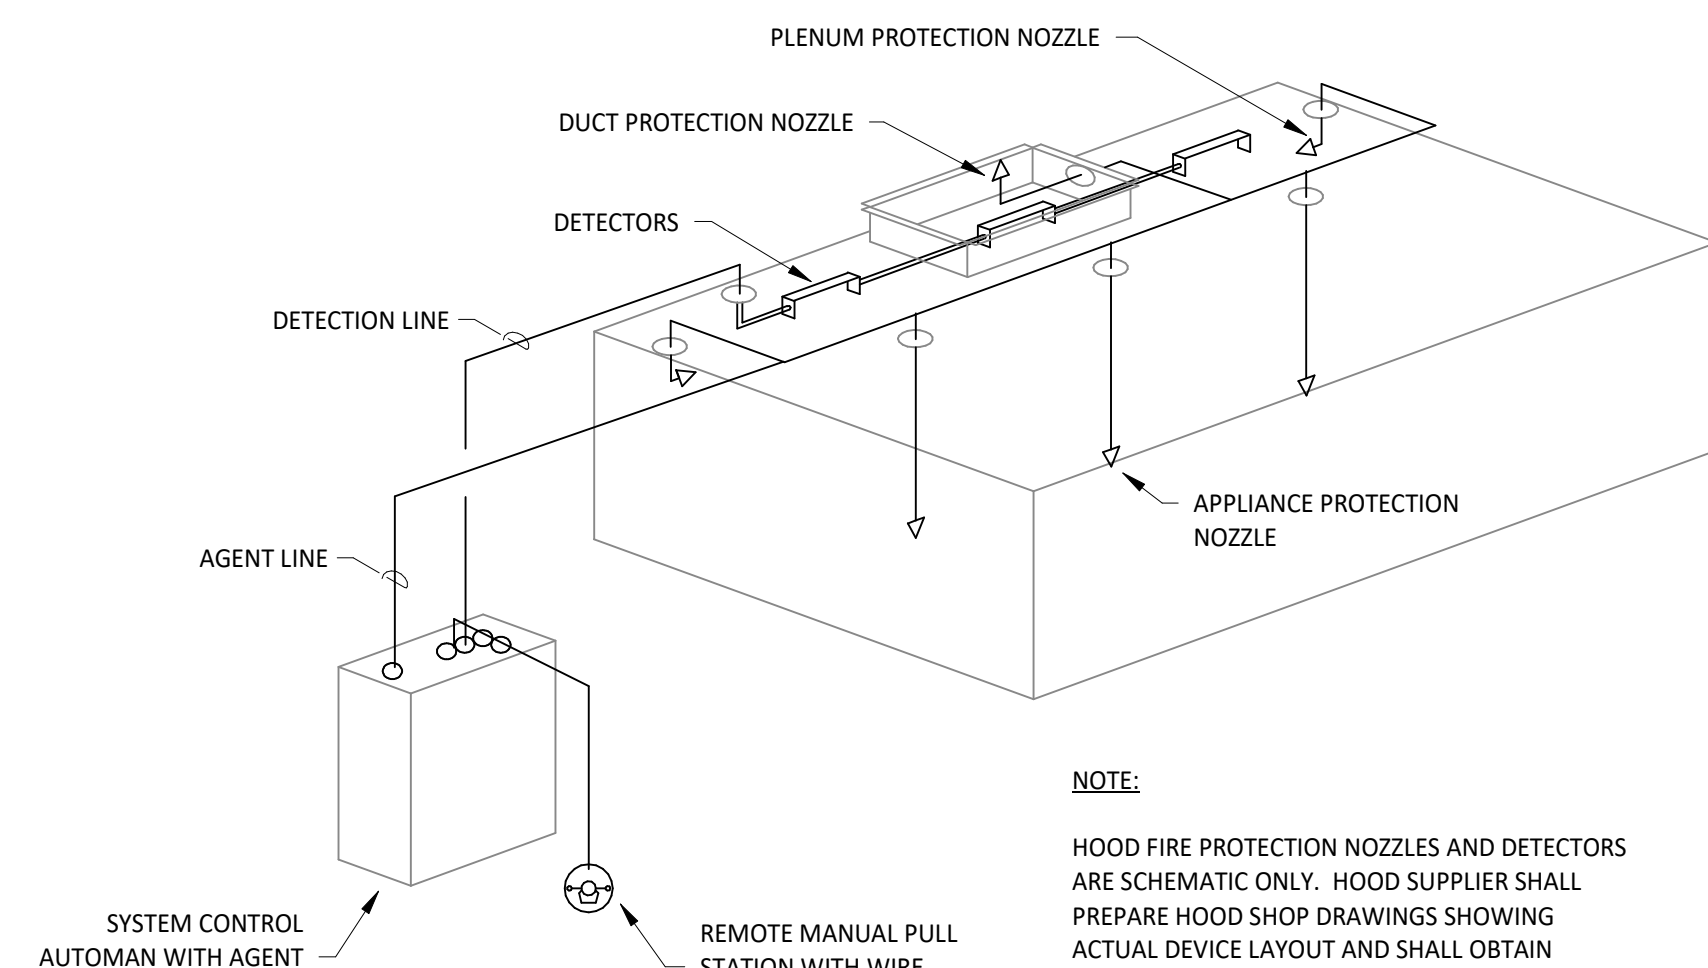


NOTE:


HOOD FIRE PROTECTION NOZZLES AND DETECTORS
ARE SCHEMATIC ONLY. HOOD SUPPLIER SHALL
PREPARE HOOD SHOP DRAWINGS SHOWING
ACTUAL DEVICE LAYOUT AND SHALL OBTAIN
PERMITS ASSOCIATED WITH THIS WORK.

4 M700 N.T.S. **FIRE SUPPRESSION SYSTEM SCHEMATIC**

1. THERMAL CERAMICS FIREMASTER FASTWRAP XL IS TESTED TO ASTM E2336 AND LISTED PER FMHKT G18 TO PROVIDE ZERO CLEARANCE TO COMBUSTIBLES AND TO PROVIDE A 1- OR 2-HOUR ENCLOSURE, THROUGH PENETRATIONS FIRESTOP SYSTEMS ARE TESTED IN ACCORDANCE WITH ASTM E 814 (UL 1479). ICC CODE EVALUATION PER REPORT UL E14229-01.
2. COMPLIANT TO THE FOLLOWING CODES:
 - NFPA 96
 - INTERNATIONAL MECHANICAL CODES
 - UNIFORM MECHANICAL CODE
 - CALIFORNIA MECHANICAL CODE
3. INSULATION APPLIED IN TWO LAYERS WITH TIGHT COMPRESSION JOINT ON BOTH LAYERS AT ALL JOINTS.
4. MINIMUM 16 GAUGE CARBON STEEL (OR 18 GAGE STAINLESS STEEL) RECTANGULAR OR ROUND GREASE EXHAUST DUCT
5. INSTALL UL LISTED AND LIQUID TIGHT THERMAL CERAMICS FASTDROK XL ACCESS DOORS, OR ALTERNATE DOOR UL LISTED PER UL1978, AT ALL CHANGES IN DIRECTION AND AT MINIMUM EVERY 20' FOR HORIZONTAL RUNS.
6. SUPPORT HANGER SYSTEMS DO NOT NEED TO BE WRAPPED PROVIDED THAT HANGER RODS ARE MINIMUM OF 3/8" IN DIAMETER AND SUPPORTS ARE MINIMUM 2 X 2 X 1/8" IN STEEL ANGLE OR 3M/ACMA EQUIVALENT SUPPORT SYSTEM.
7. THERMAL CERAMICS DUCT WRAP SHALL BE INSTALLED DIRECTLY ONTO THE DUCT AND APPLIED FROM THE HOOD CONNECTION TO THE CONNECTION TO THE FAN.
8. THERMAL CERAMICS DUCT ENCLOSURE SYSTEM SHALL BE INSTALLED IN STRICT ACCORDANCE WITH MANUFACTURERS INSTRUCTIONS AND UL LISTINGS.

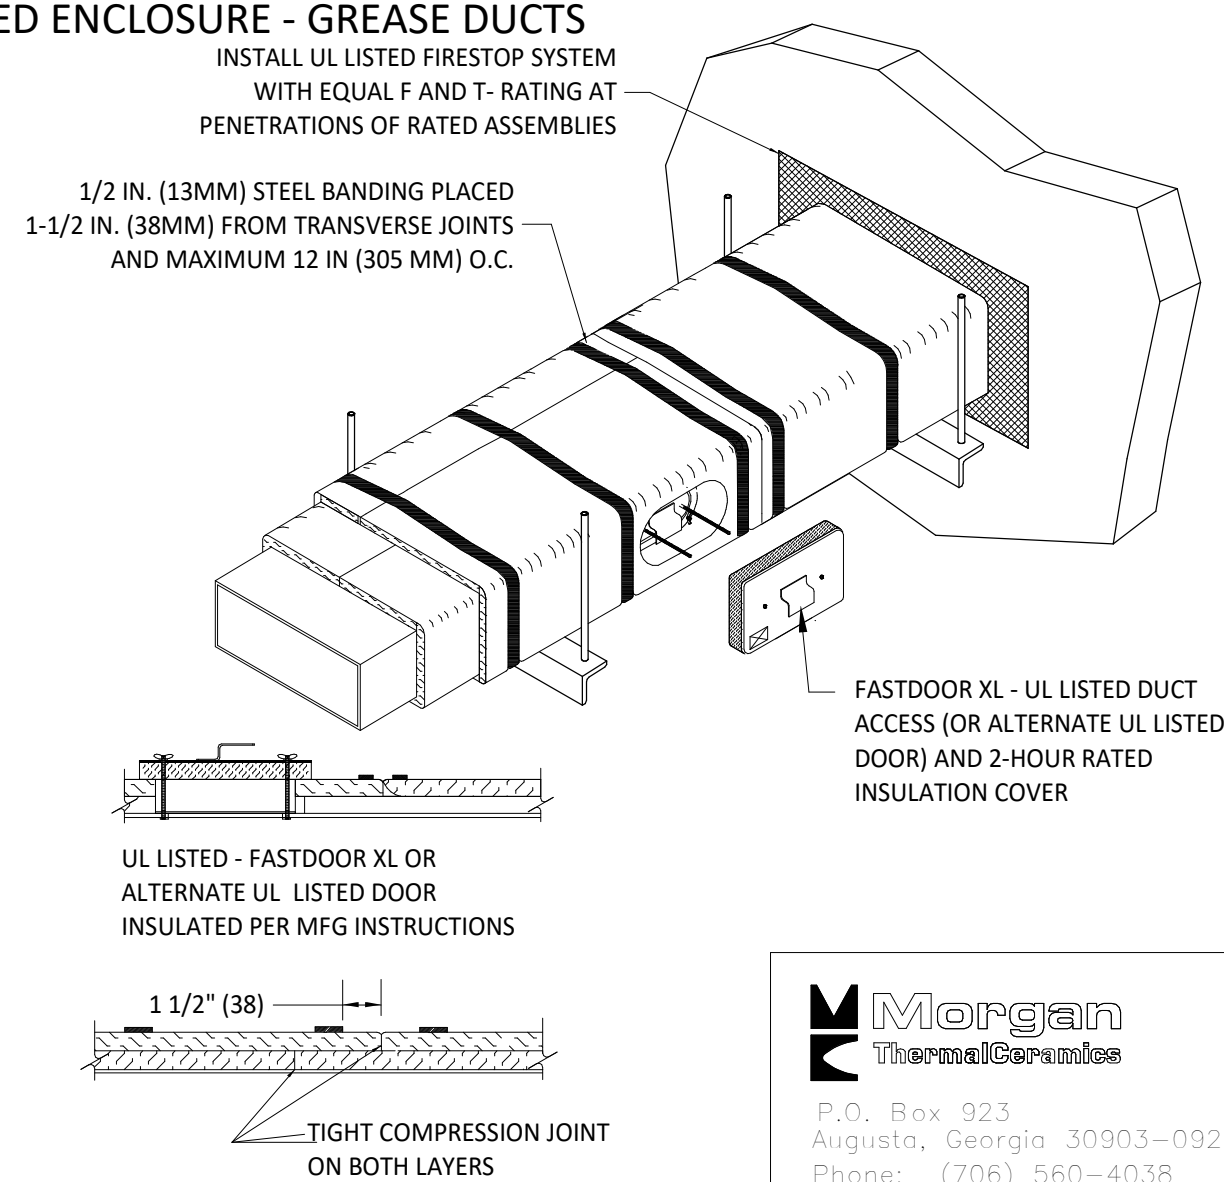


3
M700 FIREMASTER DUCT WRAP - UL HNKT-G18
N.T.S.

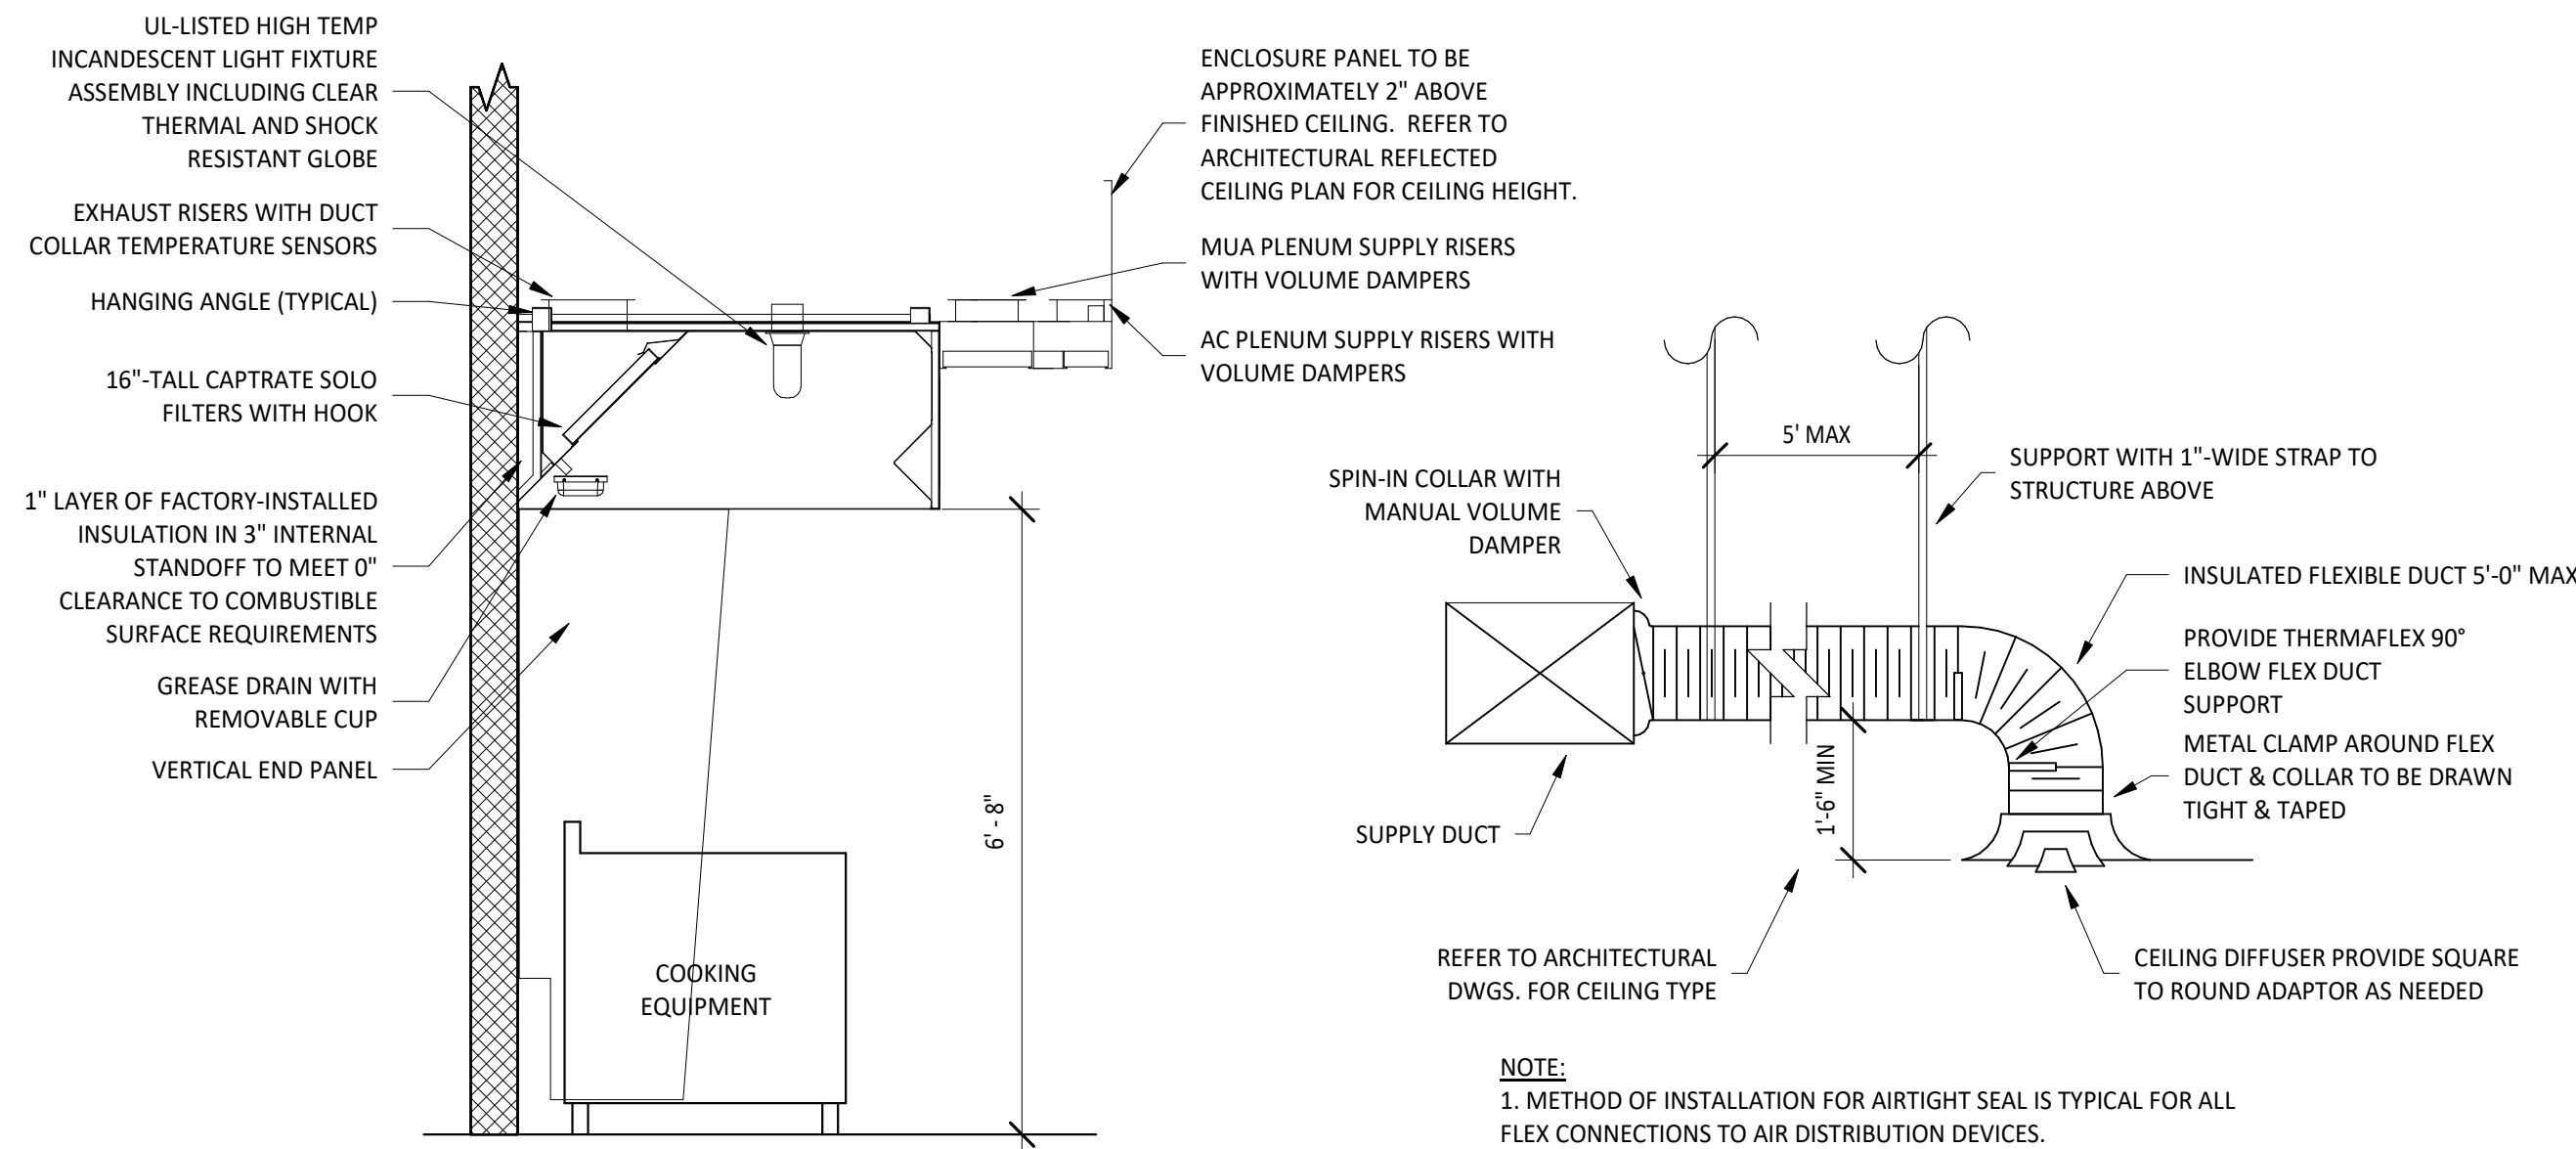


2
M700

HOOD SECTION VIEW

 N.T.S.



DIFFUSER CONNECTION

 

NATIONAL
ENGINEERING

4635 Trueman Blvd. Suite 250
Hilliard, Ohio 43026
Phone: (614) 751-9610
Fax: (614) 552-5240
Contact: Cliff Kigar
(614) 328-2033
ckigar@nationalengineering.com

FOR CONSTRUCTION



CHIPOTLE MEXICAN GRILL, INC
PO BOX 182566
COLUMBUS, OH 43218-2566
TELEPHONE: (614) 318-2400
INTERNET: WWW.CHIPOTLE.COM

STORE NO.: 4757
ANDERSON
S SCATTERFIELD RD
ANDERSON, IN 46013

Issue Record:	
<u>12/12/2023</u>	PERMIT SET
<u>05/20/2024</u>	BID SET
<u>07/24/2024</u>	CONSTRUCTION SET

Revisions:

[illegible]

Drawn: _____ Checked: _____

CJK JEJ

Project No.

2201198

Contents:

HVAC DETAILS

M700

PLUMBING FIXTURE SUPPLY CONNECTIONS

ROUGH-IN TYPE KEY											
ANGLE 3/8"		BRASS CRAFT KTR19 OR EQUAL (BRASS/CHROME 1/4 TURN ANGLED BALL STOP WITH 3/8" COMPRESSION CONNECTION)									
ANGLE 1/2"		BRASS CRAFT R39X C OR EQUAL (BRASS/CHROME MULTI-TURN ANGLED STOP WITH 1/2" COMPRESSION CONNECTION)									
ANGLE 3/4"		EVERFLOW 74342-NL W/ 3/4" SWEAT X MIP ADAPTER OR EQUAL (BRASS ANGLE STOP W/ 3/4" FIP INLET AND OUTLET)									
DIRECT		PROVIDE COPPER PIPE IN CONNECTION SIZE SHOWN TO FIXTURE									
HOSE 1/2"		ARROWHEAD BRASS WM50F OR EQUAL (BRASS/CHROME WASHING MACHINE VALVE W/ 3/4" MHT OUTLET)									
MIP		PROVIDE PIPE WITH MIP THREAD STUBBED OUT OF WALL IN CONNECTION SIZE SHOWN AND LENGTH COMPATIBLE WITH FIXTURE AND WALL MATERIAL/FINISHES.									
TAG	FIXTURE	CONNECTION SIZES		ROUGH-IN TYPE	FIXTURE UNITS (EACH)			COUNT	FIXTURE UNITS (TOTAL)		
		CW	HW		CW	HW	TOTAL		CW	HW	TOTAL
BFP-1	RPZ BACKFLOW PREVENTER	1/2"		DIRECT	1		1	1	1		1
DM-1	DISH SANITIZING MACHINE (PUMPED OUTLET)		3/4"	ANGLE 3/4"	0	1	1	1	0	1	1
ET-1	EXPANSION TANK	3/4"		DIRECT	0	0	0	1	0	0	0
HB-1	HOSE BIBB	1/2"	1/2"	MIP	1.5	1.5	2	1	1.5	1.5	4
HB-2	HOSE BIBB	1/2"		MIP	1.5	0	1.5	1	1.5	0	1.5
HS-1B	RESTROOM HAND SINK FAUCET	1/2"	1/2"	ANGLE 3/8"	1.5	1.5	2	1	1.5	1.5	4
HS-2	KITCHEN HAND SINK	1/2"	1/2"	ANGLE 3/8"	1.5	1.5	2	1	1.5	1.5	4
IM-1	ICE MAKER - BOH	1/2"		HOSE 1/2"	1	0	1	1	1	0	1
IM-2	ICE MAKER - SODA	1/2"		HOSE 1/2"	1		1	1	1		2
MB-1B	MOP BASIN FAUCET	1/2"	1/2"	MIP	2.25	2.25	3	1	2.25	2.25	3
PF-1	POT FILLER	1/2"		MIP	1.5	0	1.5	1	1.5	0	1.5
RH-1	FREEZE PROOF ROOF HYDRANT	3/4"		DIRECT	1	0	1	1	1	0	1
SK-1	THREE COMPARTMENT SINK	1/2"	1/2"	ANGLE 1/2"	4	4	4	1	4	4	4
SK-2	PREP SINK	3/4"	3/4"	ANGLE 3/4"	3	3	4	1	3	3	4
WC-1	WATER CLOSET	1/2"		ANGLE 3/8"	5	0	5	1	5	0	10
WH-1	FROST PROOF WALL HYDRANT	3/4"		DIRECT	1	0	1	1	1	0	2
WS-1	WATER SOFTENER	1"		DIRECT	0	0	0	1	0	0	0
											48

PLUMBING SUPPLY PLAN NOTES



- CONNECT TO THE EXISTING 1-1/2" DOMESTIC WATER SERVICE WITH EXISTING UPSTREAM METER AND BFP IN THE SPACE.
- PROVIDE 1/2" FILTERED WATER TO THE BAG-IN-BOX SODA CARBONATOR AT 102" AFF. SODA CARBONATOR SHALL HAVE AN INTEGRAL ASSE 1022-RATED CARBONATED BEVERAGE BACKFLOW PREVENTION DEVICE.
- PROVIDE WATER HEATER DWH-1 & DWH-2 PER DETAIL 1/P700.
- PROVIDE WATER FILTERS MOUNTED TO WALL PER DETAIL 11/P700. PROVIDE 1/2" SUPPLY PIPES FROM FILTERS TO ICE MAKER AND SODA CARBONATOR AS SHOWN.
- PROVIDE 1/2" FILTERED WATER ROUGH-IN TO THE ICE MAKER AT 56" AFF. PROVIDE 6' LONG STAINLESS STEEL FLEXIBLE BRAIDED WASHING MACHINE WATER CONNECTOR WITH MINIMUM 0.43" ID (BRASSCRAFT SL12-72WA F OR EQUAL) FOR FINAL CONNECTION TO ICE MAKER.
- PROVIDE DOMESTIC WATER ROUGH-INS FOR THE MOP BASIN FAUCET AT 36" AFF. PROVIDE DOMESTIC WATER ROUGH-INS FOR THE CHEMICAL DISPENSER FAUCET (HB-1) AT 64" AFF DIRECTLY ABOVE THE MOP BASIN FAUCET. SEE ARCHITECTURAL ELEVATION FOR ADDITIONAL INFORMATION.
- CONNECT TO THE EXISTING 2-1/2" GAS LINE WITH EXISTING UPSTREAM METER.
- PROVIDE GAS CONNECTIONS TO THE COOKING EQUIPMENT PER DETAIL 7/P700.
- SUPPORT THE GAS PIPE ON THE ROOF PER DETAIL 5/P700. WOOD BLOCKING IS NOT AN ACCEPTABLE METHOD OF SUPPORTING THE GAS PIPE.
- PROVIDE ACCESSIBLE LINE-SIZED GAS VALVE, DIRT LEG, AND UNION AT GAS CONNECTION TO THE EQUIPMENT.
- REFER TO ARCHITECTURAL DRAWINGS FOR PAINTING OF INTERIOR AND EXTERIOR EXPOSED GAS PIPE.
- PROVIDE DOMESTIC WATER ROUGH-INS FOR THE CHEMICAL DISPENSER FAUCET (HB-1) AT 52" AFF. SEE ARCHITECTURAL ELEVATION FOR ADDITIONAL INFORMATION.
- PROVIDE DOMESTIC WATER ROUGH-INS FOR THE VICTORY WASH DISPENSER FAUCET (HB-2) AT 52" AFF. SEE ARCHITECTURAL ELEVATION FOR ADDITIONAL INFORMATION.
- PROVIDE ROUGH-INS TO RESTROOM HAND SINKS AS SHOWN IN DETAIL 14/P700.
- PROVIDE KITCHEN EQUIPMENT GAS SHUTOFF 6" BELOW THE CEILING PER DETAIL 4/P700.
- CONNECT CHEMICAL DISPENSER TO HB-1. CHEMICAL DISPENSER HAS AN INTEGRAL AIR GAP AS IS SHOWN IN DETAIL 10/P700.
- PROVIDE ASSE 1016/1070 POINT-OF-USE THERMOSTATIC MIXING VALVE, WATTS LFUSG-B, ON WATER SUPPLY TO KITCHEN HAND SINKS. PROVIDE ANGLE STOP BELOW SINK, FASTEN MIXING VALVE TO WALL, AND MAKE FINAL CONNECTION FROM ANGLE STOPS TO MIXING VALVE AND FROM MIXING VALVE TO FAUCET USING BRAIDED STAINLESS STEEL HOSE. ADJUST MIXING VALVE FOR A DISCHARGE TEMPERATURE OF APPROXIMATELY 110° F.
- PROVIDE ACCESSIBLE VALVE IN WATER SUPPLY TO FIXTURE AS SHOWN.
- PROVIDE GAS CONNECTION TO THE RICE COOKER PER DETAIL 6/P700.
- PROVIDE GAS ROUGH-IN TO FRYER BEHIND RICE COOKER TABLE SO THAT VALVES AND DIRT LEG ARE ACCESSIBLE ONCE FRYER IS SECURED INTO PLACE.
- PROVIDE WATER SOFTENER AS SHOWN IN DETAIL 16/P700.
- INSTALL RGF IMSB ICE MAKER SANITIZER FURNISHED BY TUV PER CHIPOTLE'S INSTALLATION INSTRUCTIONS.
- PROVIDE 3/4" DOMESTIC HOT AND COLD WATER ROUGH-INS FOR THE PREP SINK (SK-2) FAUCET AT 24" AFF TO ALLOW FOR THE VICTORY WASH CHEMICAL DOCK TO BE INSTALLED DIRECTLY BELOW THE PREP SINK BASIN. MAKE FINAL CONNECTION TO PREP SINK FAUCET USING 3/4" BRAIDED STAINLESS STEEL WATER HEATER CONNECTOR HOSE.
- PROVIDE 3/4" HOT WATER TO THE DISH MACHINE, MAKING FINAL CONNECTION USING CONNECTION HOSE FURNISHED WITH DISH MACHINE. PROVIDE WATER HAMMER ARRESTOR ON HOT WATER LINE. PROVIDE AN ACCESSABLE SHUTOFF VALVE BELOW THE DISH MACHINE AND INSTALL THE STRAINER FURNISHED WITH THE DISH MACHINE IN AN ACCESSIBLE LOCATION AT THE CONNECTION TO THE UNIT.
- PROVIDE ROOF HYDRANT RH-1 WITH BOTTOM OF NOZZLE INSTALLED 24" ABOVE THE BOTTOM OF ROOF DECK. PROVIDE ACCESSIBLE ISOLATION VALVE IN WATER SUPPLY TO ROOF HYDRANT. SUPPORT ROOF HYDRANT PER THE MANUFACTURER'S INSTALLATION INSTRUCTIONS.
- PROVIDE FILTERED DOMESTIC WATER ROUGH-INS FOR THE SPEED FILL POT FILLER FAUCET (PF-1) AT 40" AFF. SEE ARCHITECTURAL ELEVATION FOR DETAIL.
- PROVIDE 1/2" FILTERED WATER ROUGH-IN TO THE ICE MAKER AT 24" AFF. PROVIDE 6' LONG STAINLESS STEEL FLEXIBLE BRAIDED WASHING MACHINE WATER CONNECTOR WITH MINIMUM 0.43" ID (BRASSCRAFT SL12-72WA F OR EQUAL) FOR FINAL CONNECTION TO ICE MAKER.
- INSTALL RGF IMSB ICE MAKER SANITIZER FURNISHED BY TUV PER CHIPOTLE'S INSTALLATION INSTRUCTIONS. LOCATE IMSB BELOW UTENSIL COUNTER IN A LOCATION THAT DOES NOT INTERFERE WITH THE ROLLING RACK BELOW THE UTENSIL COUNTER.
- PROVIDE ACCESSIBLE TRAP PRIMER ABOVE LAY-IN CEILING AS SHOWN. INSTALL PER MANUFACTURER'S INSTALLATION INSTRUCTIONS WITH A SERVICE VALVE AT THE TRAP PRIMER INLET. PROVIDE 1/2" DISTRIBUTION PIPE(S) TO FLOOR DRAIN TRAP PRIMER CONNECTION(S) AS SHOWN. HORIZONTAL DISTRIBUTION PIPING SHALL HAVE CONTINUOUS SLOPE TO THE FLOOR DRAIN(S).

CONNECTED GAS LOAD

FIXTURE	TAG	MBH	EQUIVALENT LENGTH FROM METER [FT]
WATER HEATER	DWH-1	199	65
WATER HEATER	DWH-2	199	65
GAS FRYER	FB-1	90	85
GRIDDLE	GR-1	107	95
MAKEUP AIR UNIT	MAU-1	225	70
RICE COOKER	RC-1	33	90
RANGE	RN-1	192	100
KITCHEN ROOFTOP UNIT	RTU-1	240	50
DINING ROOM ROOFTOP UNIT	RTU-2	240	65
Grand total		1525	MAX: 100

- NOTES:
- PRESSURE REQUIRED AFTER METER: 7" W.C.
 - DISTANCES ARE APPROXIMATE

PLUMBING SUPPLY DIAGRAM

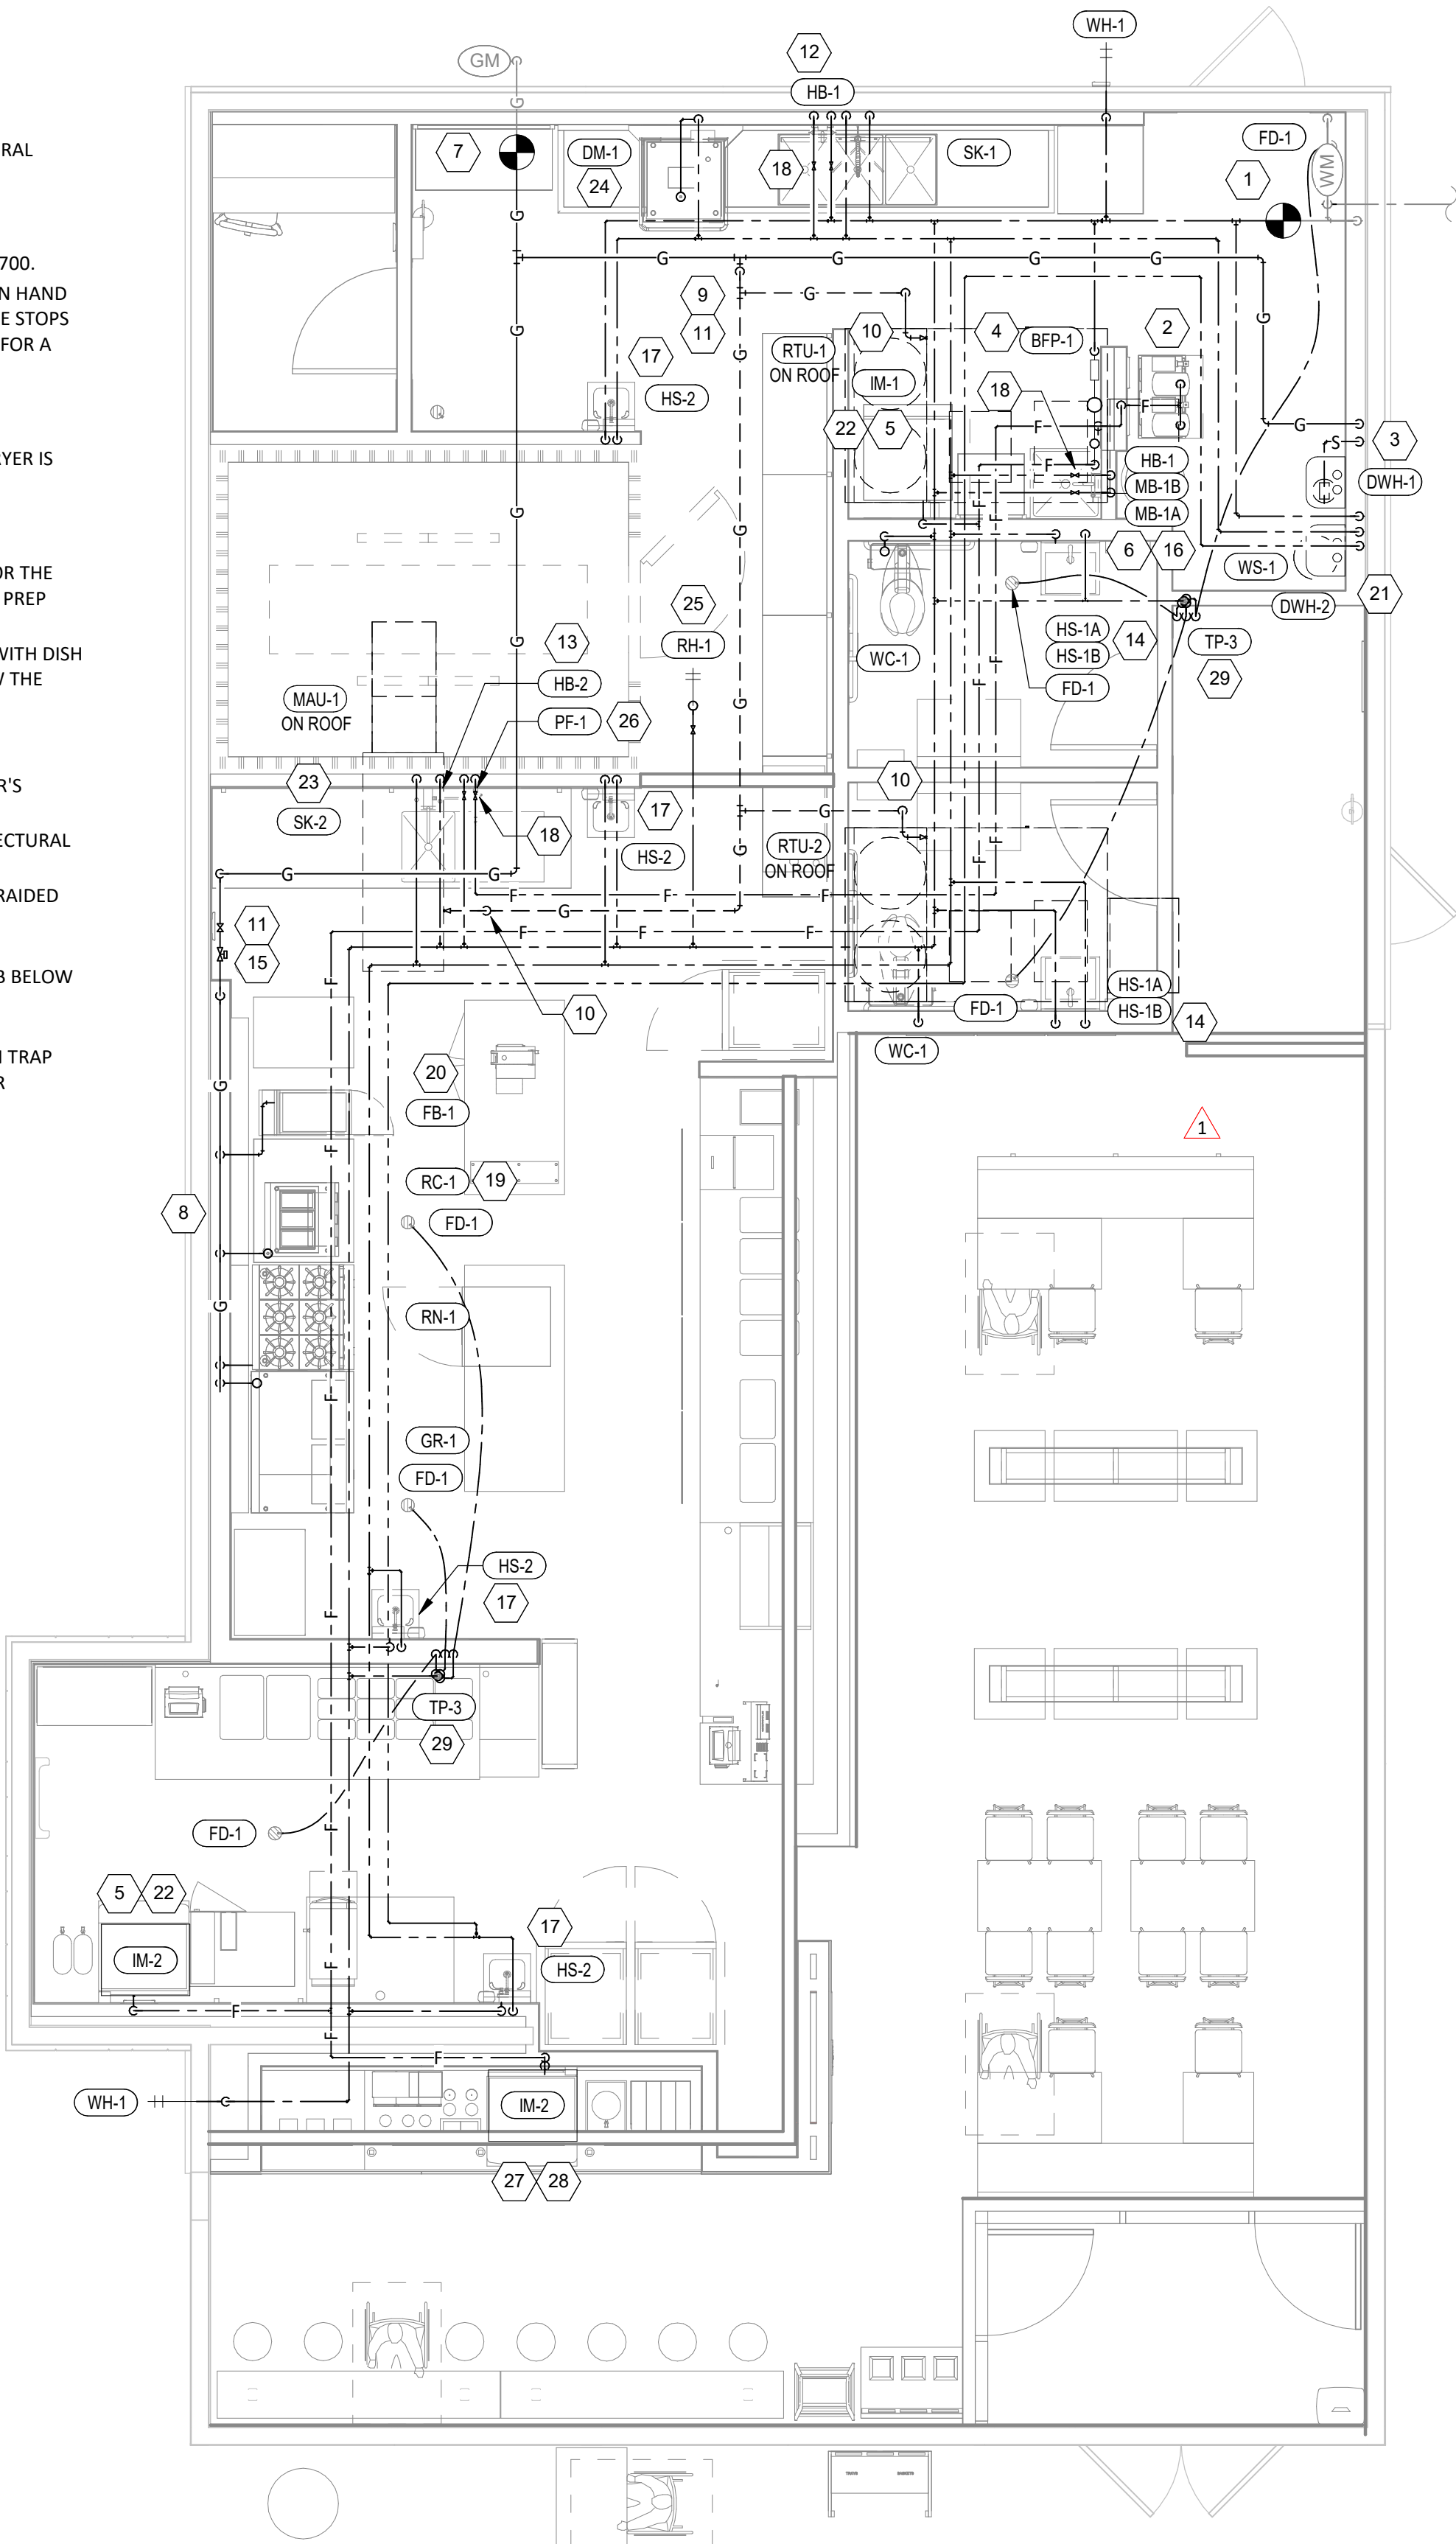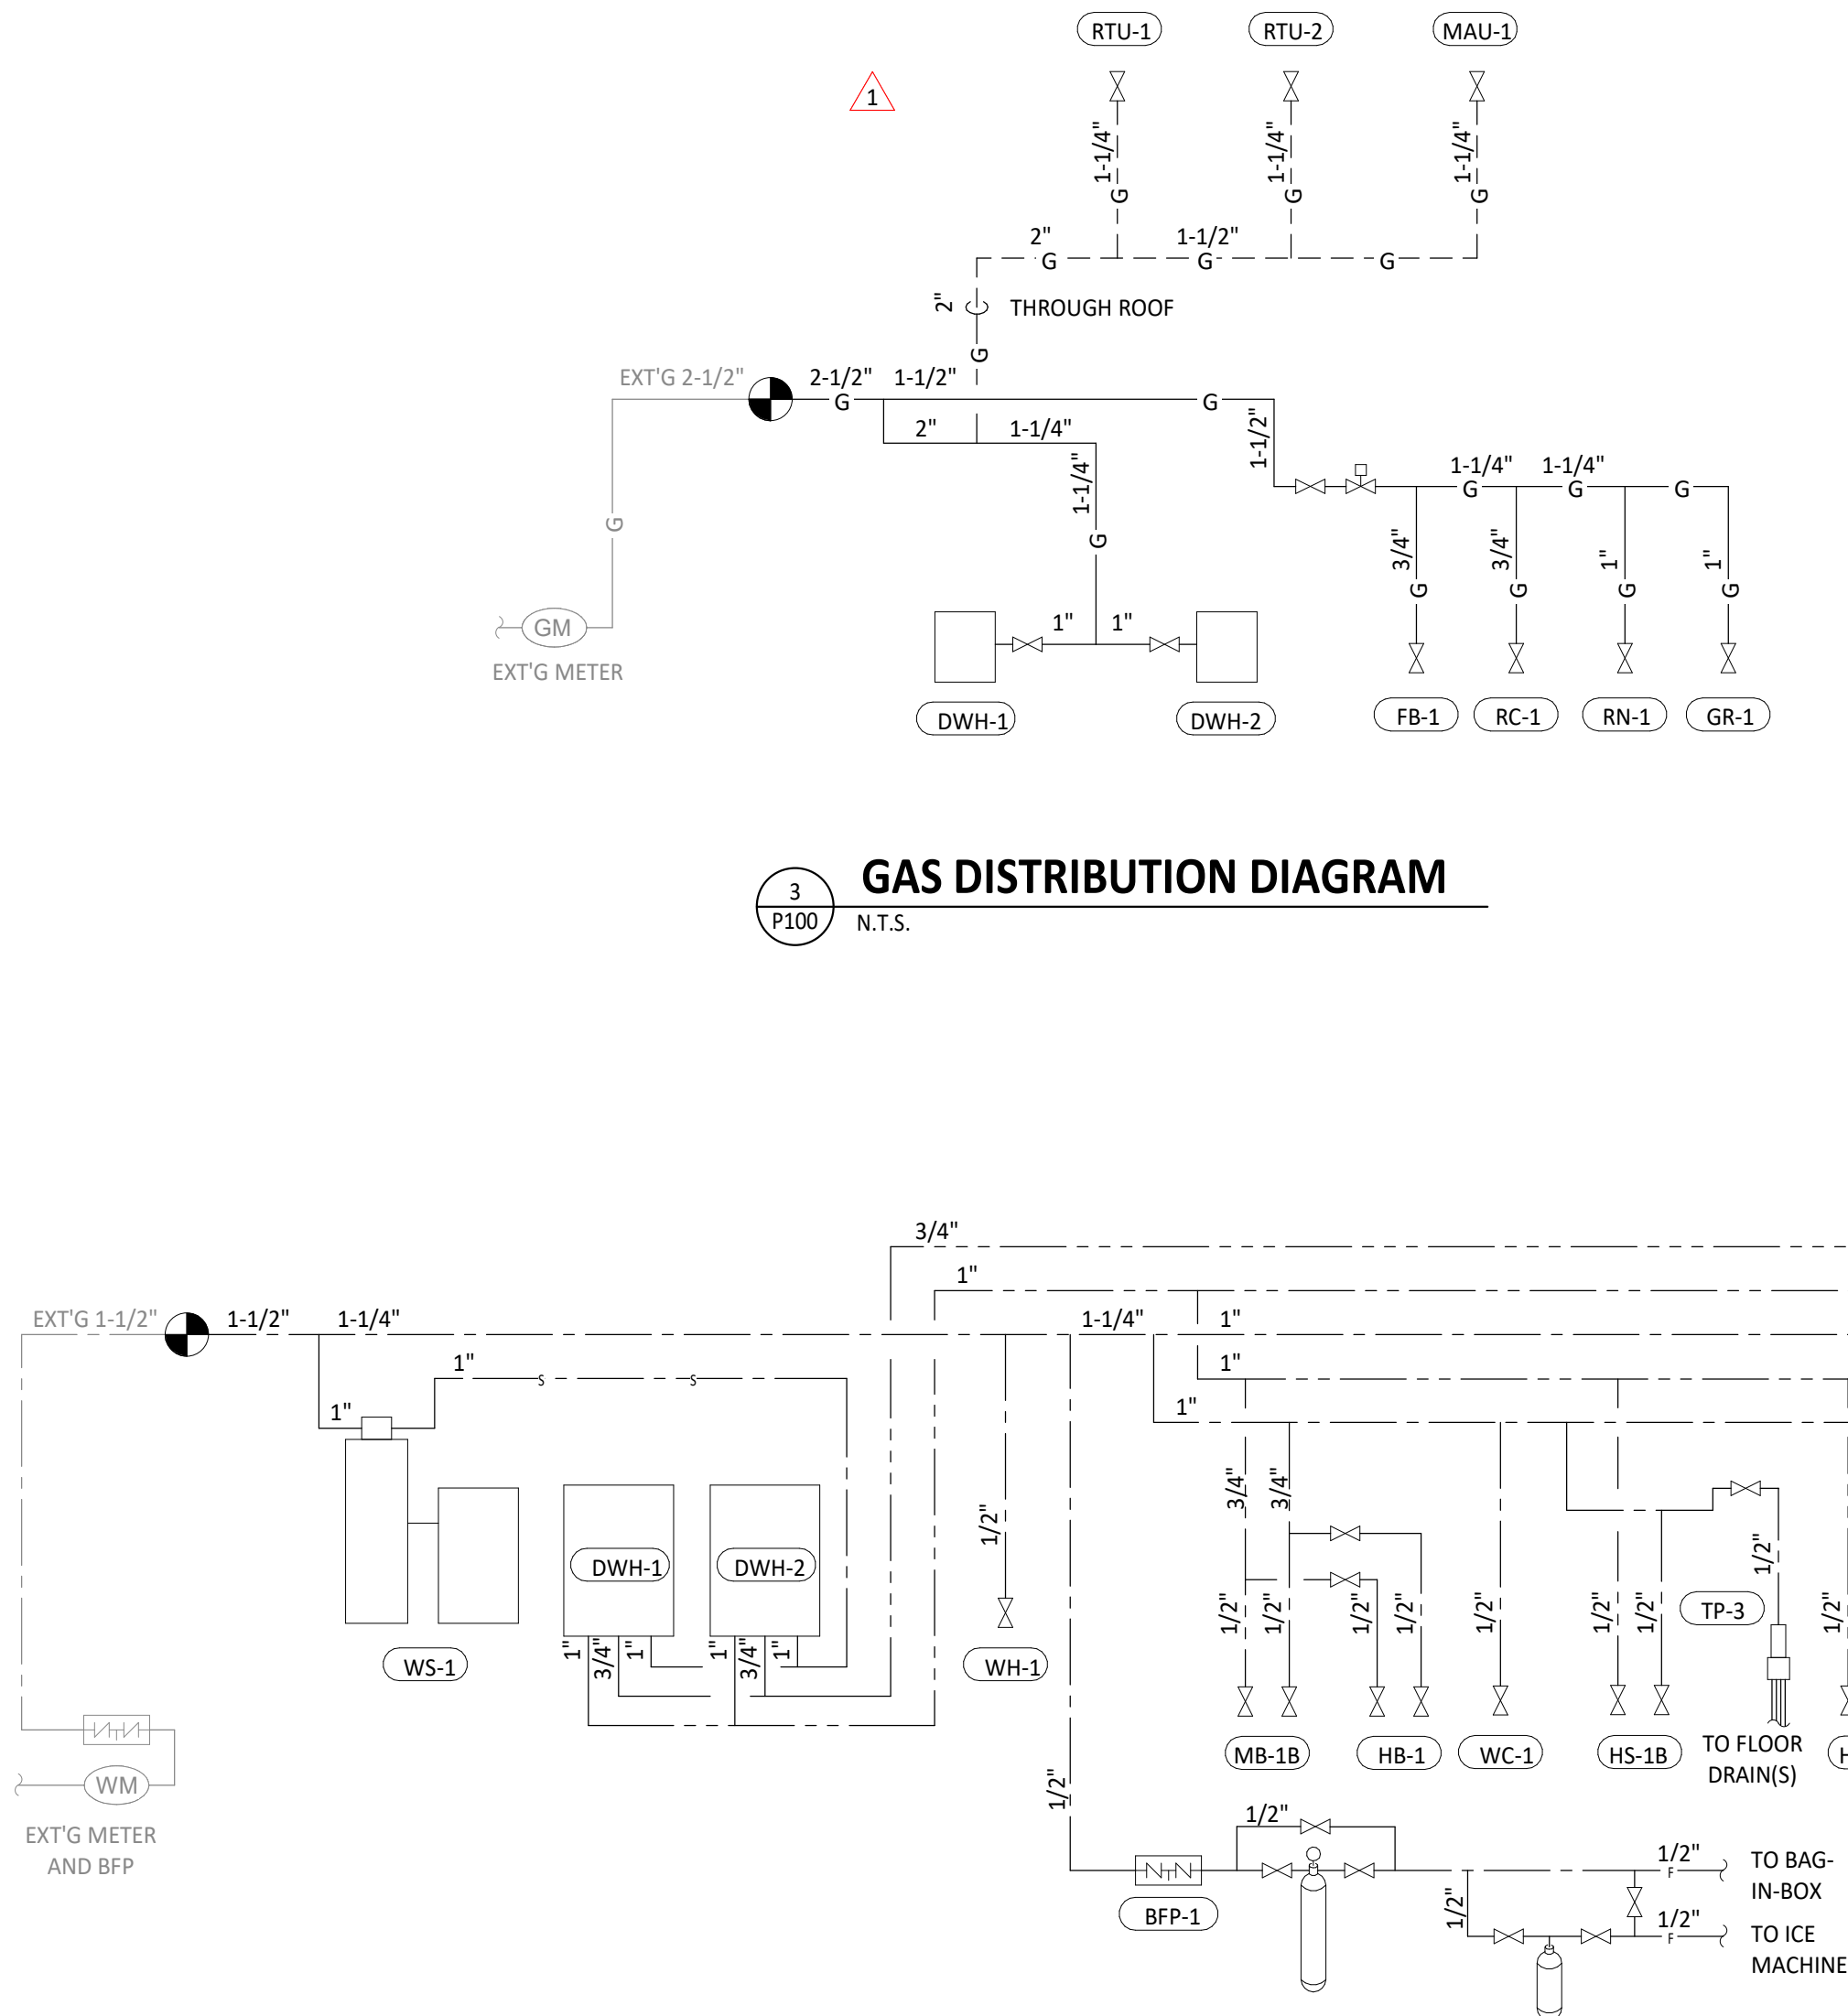

PLUMBING SUPPLY PLAN

Consultant:



4635 Trueman Blvd, Suite 250
Hilliard, Ohio 43026
Phone: (614) 751-9610
Fax: (614) 552-5240
Contact: Cliff Kigar
(614) 328-2033
ckigar@nationalengineering.com

FOR CONSTRUCTION

COPYRIGHT 2024
THIS DRAWING IS AN INSTRUMENT OF SERVICE
AND AS SUCH REMAINS THE PROPERTY OF
CHIPOTLE MEXICAN GRILL, INC.. PERMISSION FOR
USE OF THIS DOCUMENT IS LIMITED AND CAN BE
EXTENDED ONLY BY WRITTEN AGREEMENT WITH
CHIPOTLE MEXICAN GRILL, INC..



CHIPOTLE MEXICAN GRILL, INC.
PO BOX 182566
COLUMBUS, OH 43218-2566
TELEPHONE: (614) 318-2400
INTERNET: WWW.CHIPOTLE.COM

STORE NO.: 4757
ANDERSON
S SCATTERFIELD RD
ANDERSON, IN 46013

Issue Record:
12/12/2023 PERMIT SET
05/20/2024 BID SET
07/24/2024 CONSTRUCTION SET

Revisions:
1 05-20-2024 RTU REVISION

Drawn: CKJ
Checked: JEJ


Project No:
2201198

Contents:

PLUMBING PLAN
WATER & GAS

P100

Consultant:

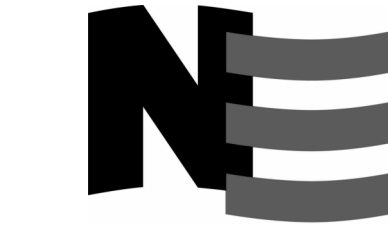

4635 Trueman Blvd, Suite 250
Hilliard, Ohio 43026
Phone: (614) 751-9610
Fax: (614) 552-5240
Contact: Cliff Kigar
(614) 328-2033
ckigar@nationalengineering.com

FOR CONSTRUCTION

COPYRIGHT 2024
THIS DRAWING IS AN INSTRUMENT OF SERVICE
AND AS SUCH REMAINS THE PROPERTY OF
CHIPOTLE MEXICAN GRILL, INC.. PERMISSION FOR
USE OF THIS DOCUMENT IS LIMITED AND CAN BE
EXTENDED ONLY BY WRITTEN AGREEMENT WITH
CHIPOTLE MEXICAN GRILL, INC..



CHIPOTLE MEXICAN GRILL, INC.
PO BOX 182566
COLUMBUS, OH 43218-2566
TELEPHONE: (614) 318-2400
INTERNET: WWW.CHIPOTLE.COM

STORE NO.: 4757
ANDERSON
S SCATTERFIELD RD
ANDERSON, IN 46013

Issue Record:
12/12/2023 PERMIT SET
05/20/2024 BID SET
07/24/2024 CONSTRUCTION SET

Revisions:
1 05-20-2024 RTU REVISION

Drawn: CJK/JEJ
Checked: JEJ/CJK

Project No:
2201198


Contents:

PLUMBING PLAN
WASTE & VENT


P110

PLUMBING WASTE AND VENT PLAN NOTES

- 1 PROVIDE 3/4" CONDENSATE DRAIN FROM THE WALK-IN COOLER EVAPORATOR TO THE FLOOR DRAIN AS SHOWN. SLOPE CONDENSATE DRAIN A MINIMUM OF 1" PER FOOT. HOLD EXPOSED CONDENSATE DRAIN IN WALK-IN COOLER AS HIGH AS POSSIBLE. CONCEAL DRAIN PIPING WITHIN FRAMED WALLS AS SHOWN. DISCHARGE THROUGH AN AIR GAP. MAKE FINAL CONNECTION TO EVAPORATOR INSIDE WALK-IN COOLER USING A UNION. CONDENSATE DRAIN SHOULD PENETRATE WALL AT 8" AFF AND BE SECURED TO FLOOR.
- 2 PROVIDE DRAIN CONNECTIONS TO THE THREE COMPARTMENT SINK PER DETAIL 2/P700.
- 3 COORDINATE ROUTING OF SODA BUNDLES WITH COCA-COLA TECHNICIAN FROM BAG-IN-BOX AREA TO EACH SODA FOUNTAIN. OTHER THAN WITHIN THE WALLS DOWN TO THE DRYER BOX THE SODA BUNDLE SHALL BE ROUTED OVERHEAD WITHOUT CONDUIT. COORDINATE SUPPORT AND ROUTING OF THE SODA LINE BUNDLES WITH COCA-COLA TECHNICIAN DURING ROUGH IN AND PROVIDE NECESSARY SUPPORTS. SEE ARCHITECTURAL DRAWINGS FOR SODA BUNDLE TERMINATION LOCATION AND PROVIDE TERMINATION PER DETAIL 12/P700.
- 4 PROVIDE PVC DRAIN PIPES FROM THE ICE MACHINE TO THE FLOOR SINK PER THE MANUFACTURER'S INSTALLATION INSTRUCTIONS. PROVIDE A CODE-APPROVED AIR GAP AT THE DISCHARGE TO THE FLOOR SINK. SECURE ICE MAKER DRAIN PIPES TO THE BOTTOM OF THE ICE MAKER.
- 5 PROVIDE DRAIN LINES FROM THE FOOD PREP SINK TO THE FLOOR SINK. PROVIDE AN AIR GAP AT THE DISCHARGE TO THE FLOOR SINK.
- 6 PROVIDE A 3" VENT THROUGH THE ROOF PER DETAIL 3/P700.
- 7 CONNECT TO EXISTING 4" GREASE WASTE LINE LEADING TO EXISTING DEDICATED 1500 GALLON INTERCEPTOR.
- 8 CONNECT TO EXISTING 4" SANITARY SEWER.
- 9 PROVIDE 3/4" VALVED DRAIN FROM HOT FOOD TABLE TO THE FLOOR SINK. DRAIN THROUGH AN AIR GAP.
- 10 PROVIDE INSULATED COPPER DRAIN LINES FROM THE TEA TRAY DRAIN AND THE SODA MACHINE DRAIN TO THE FLOOR SINK. DRAIN THROUGH AN AIR GAP. HOLD TEA TRAY DRAIN AS HIGH AS POSSIBLE AND SECURE TO STRUCTURE BELOW THE UTENSIL COUNTER.
- 11 TRIM TRENCH DRAIN ENDS PER THE MANUFACTURER'S INSTALLATION INSTRUCTIONS PRIOR TO INSTALLATION SO THAT GRATE FITS WITHOUT GAPS. INSTALL TRENCH DRAIN WITH SLIGHT POSITIVE SLOPE TOWARD THE DRAIN CONNECTION TO AVOID STANDING WATER IN TRENCH DRAIN.
- 12 SEE DETAIL 18/P700 FOR DRAINS FROM TEA TRAY, ICE MAKER, AND SODA MACHINE TO FUNNEL DRAIN.
- 13 DO NOT PROVIDE WALL CLEANOUTS ON TILE OR PUBLICLY-VISIBLE WALLS. IF A WALL CLEANOUT IS REQUIRED ON THESE SURFACE COORDINATE THE EXACT LOCATION WITH CHIPOTLE'S CONSTRUCTION MANAGER.
- 14 PROVIDE INDIRECT WASTE AND CONDENSATE DRAINS FROM FIXTURES OTHER THAN KITCHEN SINKS CONCEALED IN THE WALL AS SHOWN IN DETAIL 9/P700.
- 15 PROVIDE DRAIN FROM WATER FILTER BFP TO MOP SINK CONCEALED IN THE WALL AS SHOWN IN DETAIL 9/P700.
- 16 PROVIDE TRENCH DRAIN AS SHOWN IN DETAIL 15/P700.
- 17 INSTALL DRAIN HOSE FURNISHED WITH DISH MACHINE FROM DISH MACHINE OUTLET TO FLOOR SINK. HOLD DRAIN HOSE TIGHT TO WALL AND SECURE TO 3-COMP SINK DRAIN TO MAINTAIN AN AIR GAP AT THE FLOOR SINK.
- 18 PROVIDE CONDENSATE TRAP ON RTU PER DETAIL 13/P700.
- 19 PROVIDE 3/4" PVC DRAIN PIPE FROM THE ICE MACHINE TO THE FLOOR SINK PER THE MANUFACTURER'S INSTALLATION INSTRUCTIONS. PROVIDE A CODE-APPROVED AIR GAP AT THE DISCHARGE TO THE FLOOR SINK.

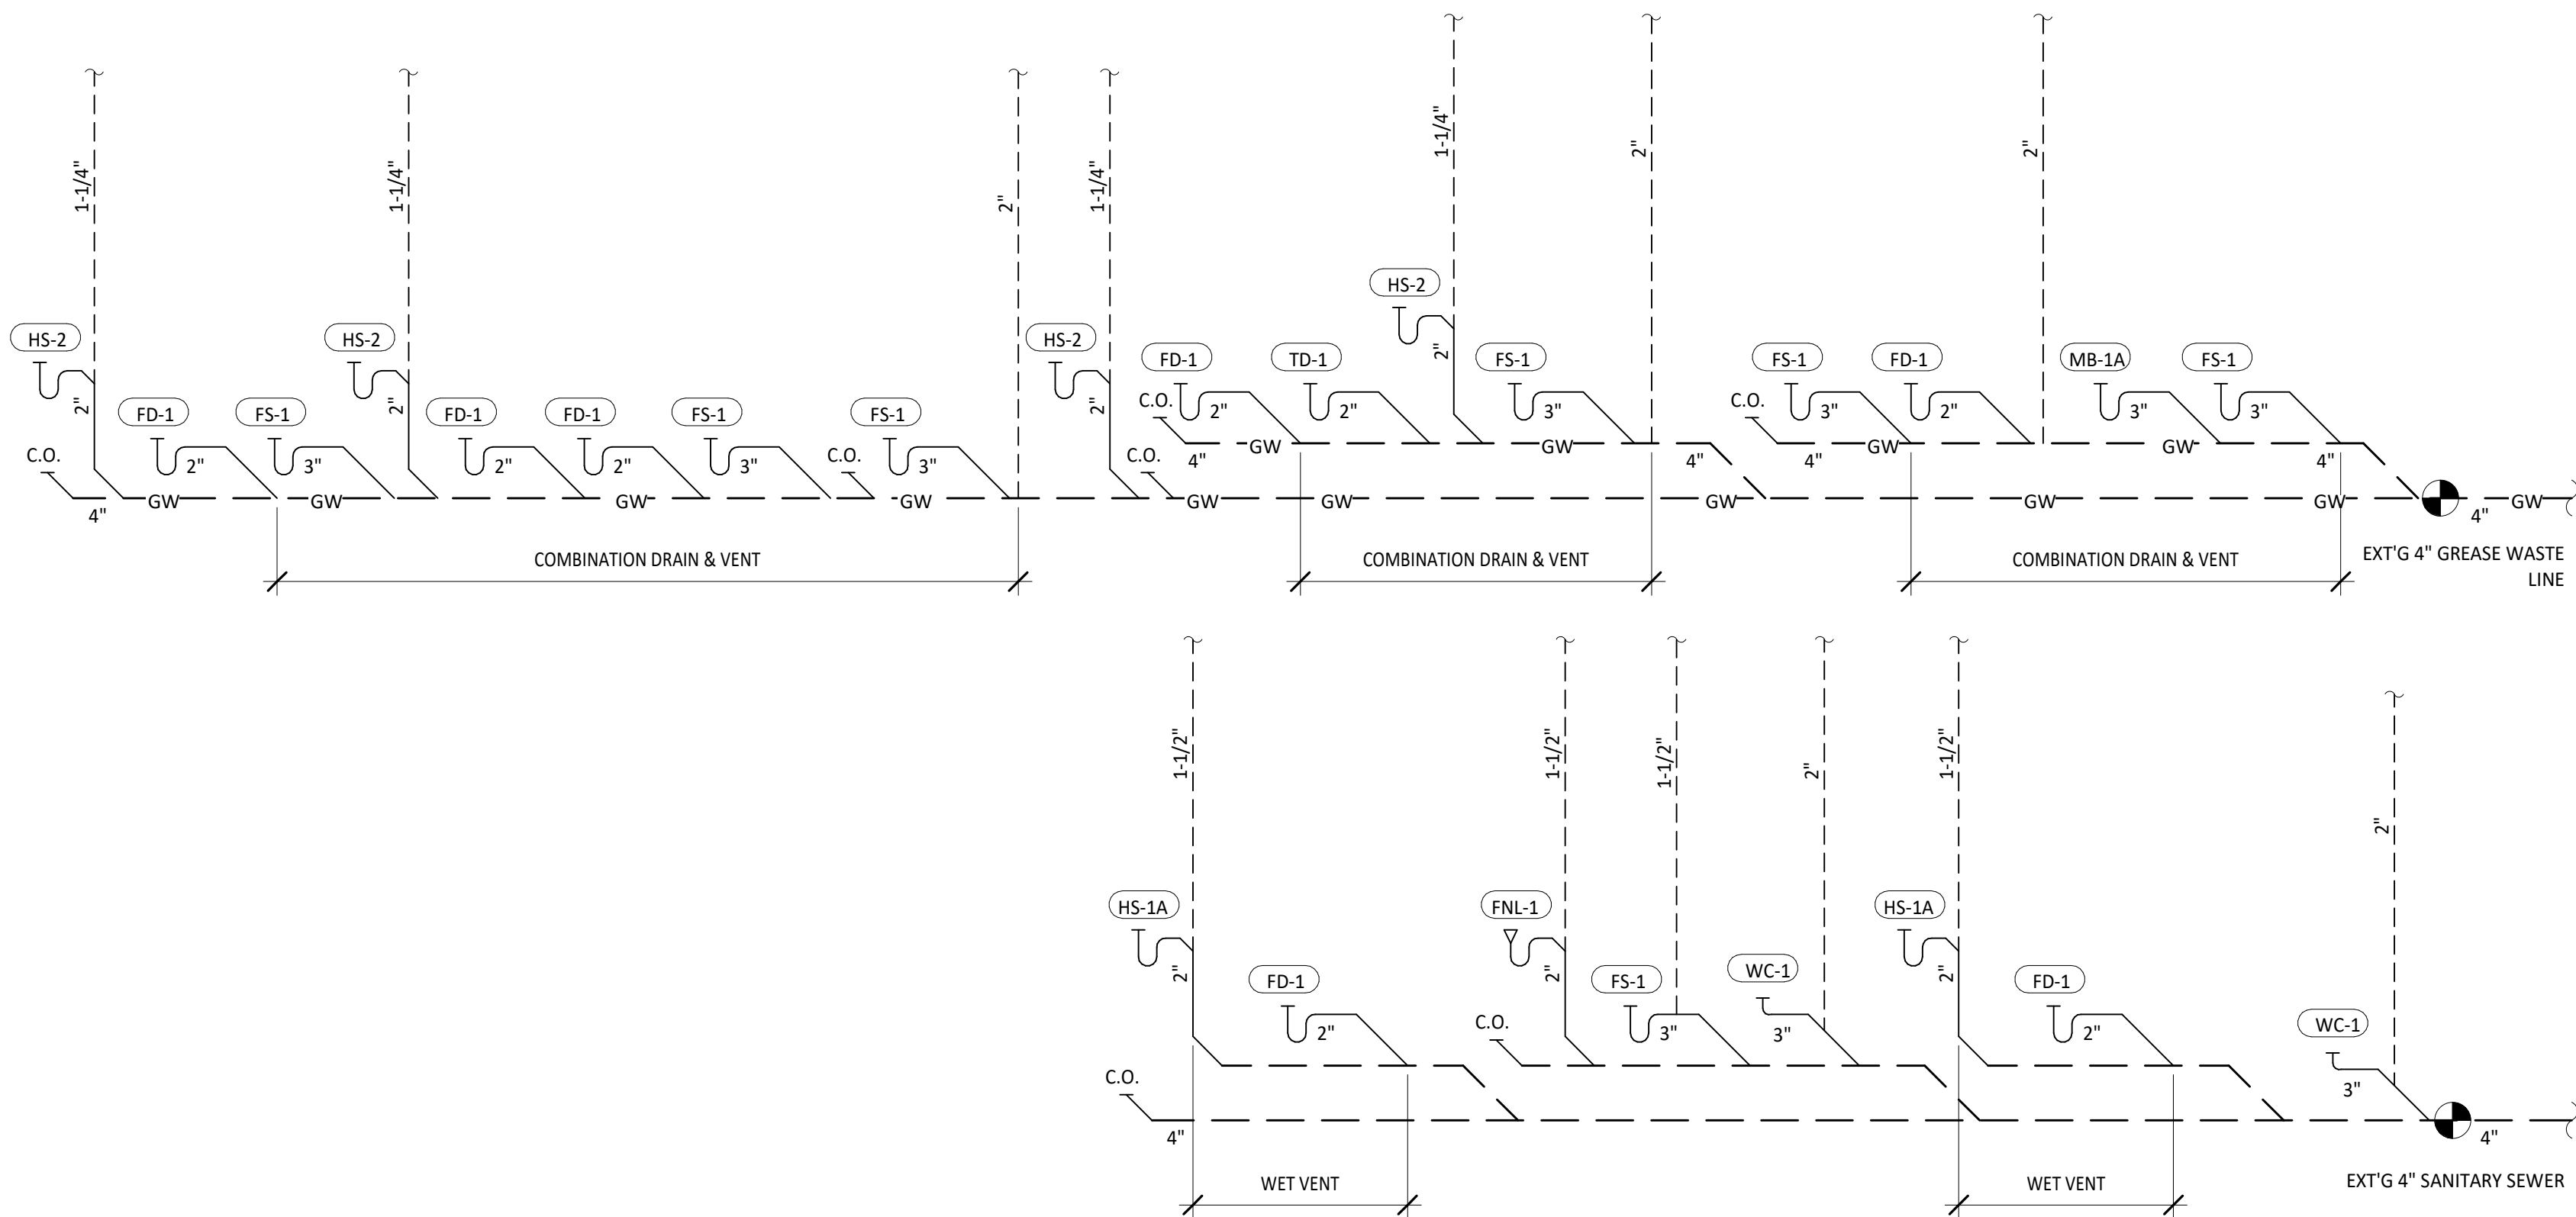

2 P110 SANITARY WASTE & VENT DIAGRAM
N.T.S.

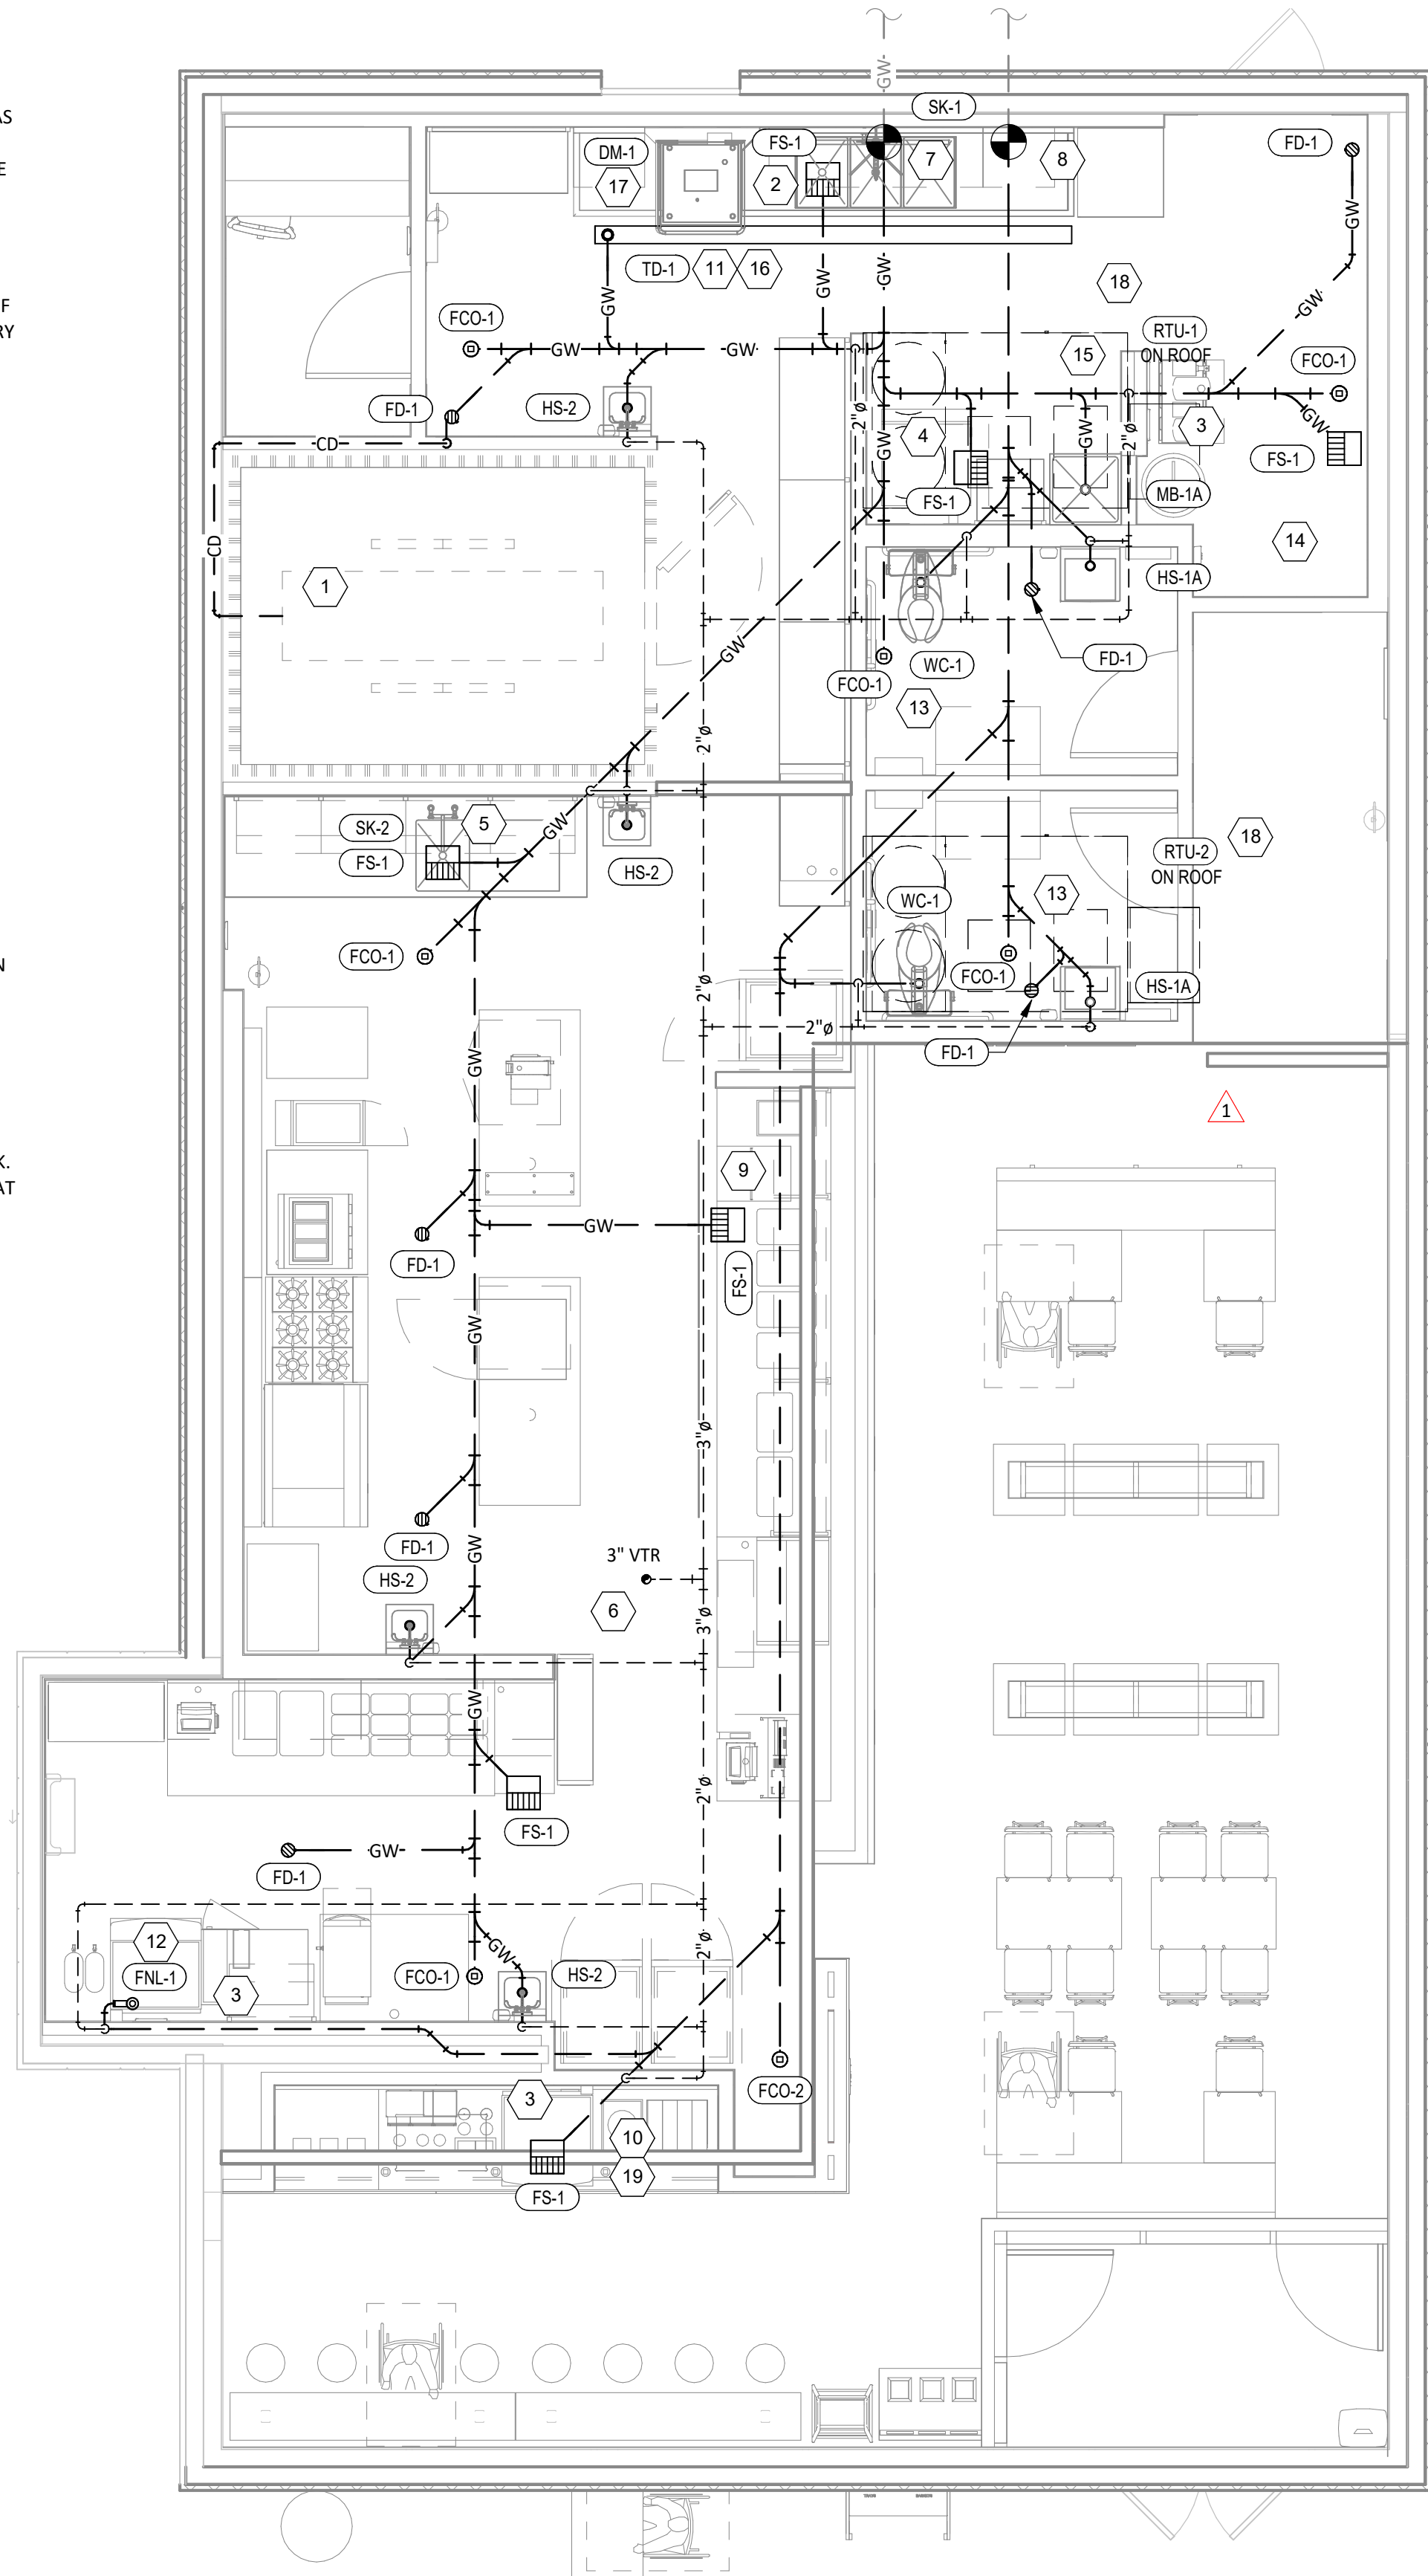

1 P110 SANITARY WASTE & VENT PLAN
1/4" = 1'-0"

PLUMBING FIXTURE SCHEDULE

TAG	FIXTURE	FURNISHED BY	INSTALLED BY	MANUFACTURER	MODEL	DESCRIPTION	QUANTITY		CONNECTION SIZES			FIXTURE UNITS (EACH)				FIXTURE UNITS (TOTAL)			
									CW	HW	WASTE	CW	HW	TOTAL	SAN	CW	HW	TOTAL	SAN
BFP-1	RP2 BACKFLOW PREVENTER	GC	GC	CONBRACO	4ALF-203-T2F	LEAD FREE REDUCED PRESSURE PRINCIPLE BACKFLOW PREVENTER WITH AUTOMATIC DIFFERENTIAL RELIEF VALVE	1		1/2"			1		1		1	0	1	0
DM-1	DISH SANITIZING MACHINE (PUMPED OUTLET)	KES	GC	FURNISHED BY KES	--	CHEMICAL SANITIZING DISH MACHINE WITH INTEGRAL ELECTRIC BOOSTER HEATER AND PUMPED OUTLET	1			3/4"	3/4"	0	1	1	0	0	1	1	0
ET-1	EXPANSION TANK	GC	GC	AMTROL	ST-5	2 GALLON CAPACITY	1		3/4"			0	0	0	0	0	0	0	0
FCO-1	FLOOR CLEANOUT (4")	GC	GC	SIOUX CHIEF	852-4PNR	ON-GRADE ADJUSTABLE CLEANOUT WITH INTERNAL THREADED CLEANOUT PLUG AND ROUND NICKEL-BRONZE RING AND COVER (OR APPROVED EQUAL WITH INTERNAL THREADED CLEANOUT PLUG)	6				4"				0	0	0	0	0
FCO-2	FLOOR CLEANOUT (3")	GC	GC	SIOUX CHIEF	852-3PNR	ON-GRADE ADJUSTABLE CLEANOUT WITH INTERNAL THREADED CLEANOUT PLUG AND ROUND NICKEL-BRONZE RING AND COVER (OR APPROVED EQUAL WITH INTERNAL THREADED CLEANOUT PLUG)	1				3"				0	0	0	0	0
FD-1	FLOOR DRAIN	GC	GC	SIOUX CHIEF	842-2-PNR	ADJUSTABLE FLOOR DRAIN, ROUND POLISHED METAL RING AND STRAINER	7				2"			0	2	0	0	0	14
FNL-1	FUNNEL DRAIN	GC	GC	JAY R. SMITH	3832T	FUNNEL DRAIN WITH CAST BRONZE BODY AND THREADED OUTLET	1				2"	0	0		2	0	0	0	2
FS-1	FLOOR SINK	GC	GC	SIOUX CHIEF	861-3PU2	HEAVY DUTY PVC FLOOR SINK WITH ALUMINUM DOME BOTTOM STRAINER AND OPEN HALF PVC GRATE	7				3"			0	5	0	0	0	35
HB-1	HOSE BIBB	KES	GC	T&S	B-2345-01-XX	COMMERCIAL QUALITY HOT & COLD MIXING WALL HYDRANT. SUPPLY ARMS SHALL HAVE INTEGRAL SHUT-OFF STOP AND CHECK VALVE.	2		1/2"	1/2"		1.5	1.5	2	0	3	3	4	0
HB-2	HOSE BIBB	KES	GC	T&S	B-0730	SILL FAUCET WITH 1/2" NPT FEMALE INLET AND 3/4" GARDEN HOSE THREADED OUTLET.	1		1/2"			1.5	0	1.5	0	1.5	0	1.5	0
HS-1A	RESTROOM HAND SINK	GC	GC	KOHLER	K-2084	ADA-ACCESSIBLE, WALL-MOUNTED, PORCELAIN LAVATORY. PROVIDE ZURN Z1231 (Z1231-D FOR BACK-TO-BACK APPLICATIONS) CONCEALED ARM CARRIER IN WALL.	2		0"	0"	2"	0	0	0	1	0	0	0	2
HS-1B	RESTROOM HAND SINK FAUCET	KES	GC	FURNISHED BY KES	--	PLUG-IN AUTOMATIC FAUCET WITH 0.5 GPM AERATOR AND THERMOSTATIC MIXING VALVE. ADJUST FAUCET CONTROLS FOR 10 SECOND SHUTOFF DELAY AND 30 SECOND TIME-OUT DELAY.	2		1/2"	1/2"	0"	1.5	1.5	2	0	3	3	4	0
HS-2	KITCHEN HAND SINK	KES	GC	FURNISHED BY KES	--	STAINLESS STEEL SINK WITH WALL MOUNTING BRACKET AND BACKSPLASH MOUNTED FAUCET WITH SWIVEL GOOSENECK	4		1/2"	1/2"	2"	1.5	1.5	2	1	6	6	8	4
IM-1	ICE MAKER - BOH	KES	GC	SEE ARCH	--	BACK OF HOUSE ICE MAKER WITH BIN	1		1/2"			1	0	1	0	1	0	1	0
IM-2	ICE MAKER - SODA	KES	KES	SEE ARCH	--	SODA MACHINE-MOUNTED ICE MAKER	2		1/2"			1		1		2	0	2	0
MB-1A	MOP BASIN	GC	GC	FIAT	MSB2424	PROVIDE 24"x24"x10" MOLDED-STONE MOP BASIN. INSTALL MOP BASIN IN A BED OF GROUT SO THERE ARE NO VOIDS BETWEEN THE MOP BASIN AND THE SLAB.	1		0"	0"	3"	0	0	0	3	0	0	0	3
MB-1B	MOP BASIN FAUCET	KES	GC	FURNISHED BY KES	--	SERVICE SINK FAUCET WITH BUILT IN STOPS, LEVER HANDLES, AND WALL BRACE.	1		1/2"	1/2"	0"	2.25	2.25	3	0	2.25	2.25	3	0
PF-1	POT FILLER	KES	GC	FURNISHED BY KES	--	WALL-MOUNTED POT FILLER W/ SELF-CLOSING FILLER VALVE AND 3/8" NPT FEMALE INLET	1		1/2"			1.5	0	1.5		1.5	0	1.5	0
RH-1	FREEZE PROOF ROOF HYDRANT	GC	GC	HOEPTNER	2131R	AUTOMATIC DRAINING, FREEZELESS ROOF HYDRANT WITH ANTI-SIPHON VACUUM BREAKER HOEPTNER PRODUCTS (408) 847-7615	1		3/4"			1	0	1		1	0	1	0
SK-1	THREE COMPARTMENT SINK	KES	GC	FURNISHED BY KES	--	THREE-COMPARTMENT WARE-WASHING SINK FURNISHED WITH (1) PRE-RINSE UNIT WITH ADD-ON FAUCET	1		1/2"	1/2"	2"	4	4	4	5	4	4	4	5
SK-2	PREP SINK	KES	GC	FURNISHED BY KES	--	STAINLESS STEEL PREP TABLE WITH INTEGRAL PREP SINK. FURNISHED WITH "BIG FLO" FAUCET	1		3/4"	3/4"	2"	3	3	4	0	3	3	4	0
TD-1	TRENCH DRAIN	GC	GC	ZURN	Z886 8601 8602	6" X 160" HDPE TRENCH DRAIN (SLOPED FROM 3.50" TO 4.70") WITH (2) CLOSED END CAPS, (1) 4" NO-HUB BOTTOM OUTLET, AND CLASS-A HEEL-PROOF POLYETHYLENE GRATES. SEE DETAIL 12/P700 FOR REDUCTION TO 2" DRAIN CONNECTION.	1				2"	0	0	0	2	0	0	0	2
TP-3	TRAP PRIMER (THREE-FOUR FLOOR DRAINS)	GC	GC	PRECISION PLUMBING PRODUCTS	P1-500 W/ DU-U	TRAP PRIMER WITH INTEGRAL VACUUM BREAKER AND DISTRIBUTION UNIT. CAP UNUSED DISTRIBUTION UNIT OUTLETS.	2		1/2"			0		0		0	0	0	0
WC-1	WATER CLOSET	GC	GC	KOHLER	K-3519 W/ SEAT K-4666-C	WHITE HIGHLINE 1.0 GPF, 17-1/8"-HIGH, ADA ACCESSIBLE, PRESSURE ASSIST WATER CLOSET WITH OPEN-FRONT SEAT. INSTALL TRIP LEVER ON THE TANK TO THE OPEN SIDE OF THE STALL (ADD -RA TO THE MODEL # FOR RIGHT HAND TRIP LEVER).	2		1/2"		3"	5	0	5	4	10	0	10	8
WH-1	FROST PROOF WALL HYDRANT	GC	GC	WOODFORD	MODEL 65	AUTOMATIC DRAINING, FREEZELESS WALL HYDRANT WITH ANTI-SIPHON VACUUM BREAKER. PROVIDE WITH STEM LONG ENOUGH TO REACH INSIDE THE THERMAL ENVELOPE OF THE BUILDING.	2		3/4"			1	0	1		2	0	2	0
WS-1	WATER SOFTENER	KES	GC	CUNO	CFSM1254E	POINT OF ENTRY HIGH CAPACITY WATER TREATMENT SYSTEM	1		1"			0	0	0	0	0	0	0	0
							53					0	0	0	0	41.25	22.25	48	75

WATER HEATER SCHEDULE - INSTANTANEOUS

TAG	DESCRIPTION	FURNISHED BY	INSTALLED BY	MANUFACTURER	MODEL	INPUT MBH	DELIVERY	NOTES
DWH-1	DIRECT VENT GAS-FIRED INSTANTANEOUS WATER HEATER	GC	GC	NAVIENT	NPE-240A2	199	354 GPH @ 65" RISE	RATED FLOW RATE: 5.6 GPM @ 67°F RISE THERMAL EFFICIENCY: 96% PROVIDE WITH LEAD FREE "PLUMB EASY VALVE SET". GC SHALL PURCHASE WATER HEATER DIRECTLY THROUGH A NAVIENT AUTHORIZED DISTRIBUTOR (1-800-519-8794 OR WWW.NAVIENT.COM TO LOCATE AUTHORIZED DISTRIBUTOR).
DWH-2	DIRECT VENT GAS-FIRED INSTANTANEOUS WATER HEATER	GC	GC	NAVIENT	NPE-240A2	199	354 GPH @ 65" RISE	RATED FLOW RATE: 5.6 GPM @ 67°F RISE THERMAL EFFICIENCY: 96% PROVIDE WITH LEAD FREE "PLUMB EASY VALVE SET". GC SHALL PURCHASE WATER HEATER DIRECTLY THROUGH A NAVIENT AUTHORIZED DISTRIBUTOR (1-800-519-8794 OR WWW.NAVIENT.COM TO LOCATE AUTHORIZED DISTRIBUTOR).

consultant:



4635 Trueman Blvd. Suite 250
Hilliard, Ohio 43026
Phone: (614) 751-9610
Fax: (614) 552-5240
Contact: Cliff Kigar
(614) 328-2033
ckigar@nationalengineering.com

FOR CONSTRUCTION

COPYRIGHT 2024
THIS DRAWING IS AN INSTRUMENT OF SERVICE
AND AS SUCH REMAINS THE PROPERTY OF
CHIPOTLE MEXICAN GRILL, INC.. PERMISSION FOR
USE OF THIS DOCUMENT IS LIMITED AND CAN BE
EXTENDED ONLY BY WRITTEN AGREEMENT WITH
CHIPOTLE MEXICAN GRILL, INC..



CHIPOTLE MEXICAN GRILL, INC.
PO BOX 182566
COLUMBUS, OH 43218-2566
TELEPHONE: (614) 318-2400
INTERNET: WWW.CHIPOTLE.COM

STORE NO.: 4757
ANDERSON
S SCATTERFIELD RD
ANDERSON, IN 46013

Sue Record:

2/12/2023	PERMIT SET
5/20/2024	BID SET
7/24/2024	CONSTRUCTION SET

Revisions:

[illegible]

Drawn:	Checked:
JK	JEJ

Project No.

201198

Contents:

PLUMBING SCHEDULES

P600



- WATER HEATER GENERAL NOTES**
- A. CLEAN INLET STRAINERS AFTER CONSTRUCTION HAS BEEN COMPLETED AND PRIOR TO TURNOVER OF THE BUILDING TO THE TENANT.
 - B. INSTALL PIPING WITH AS FEW ELBOWS AS POSSIBLE.
 - C. MAINTAIN REQUIRED CLEARANCE TO COMBUSTIBLE MATERIALS.
 - D. ADJUST WATER HEATER TO A SETPOINT OF 120° F.

P700

LIGHTING CONTROL PANEL SCHEDULE: LCP

RELAY	PANEL	CIRCUIT	AREA SERVED	CONTROL	TIME ON	TIME OFF	DIMMER CONTROL	NOTES
R1	A	30	KITCHEN A	TIMECLOCK	7:00:00 AM	12:00:00 AM	N/A	SINGLE POLE (NC)
R2	A	30	KITCHEN B	TIMECLOCK	7:00:00 AM	12:00:00 AM	N/A	SINGLE POLE (NC)
R3			SPARE				N/A	SINGLE POLE (NC)
R4	A	32	DINING ROOM A	TIMECLOCK	10:00:00 AM	12:00:00 AM	N/A	SINGLE POLE (NC)
R5	A	32	DINING ROOM B	TIMECLOCK	10:00:00 AM	12:00:00 AM	N/A	SINGLE POLE (NC)
R6	A	32	DINING ROOM DL	TIMECLOCK	10:00:00 AM	12:00:00 AM	N/A	SINGLE POLE (NC)
R7	A	28	RESTROOM EXHAUST FAN	TIMECLOCK	7:00:00 AM	12:00:00 AM	N/A	SINGLE POLE (NC)
R8	A	40	EXT. LIGHTING/SIGNAGE	TIMECLOCK	SUNSET - 1 HR	12:00:00 AM	N/A	SINGLE POLE (NC)

LIGHTING CONTROL COMPONENTS SCHEDULE

	DESCRIPTION	QUANTITY	FURNISHED BY	INSTALLED BY	MANUFACTURER	MODEL	REMARKS
LCP	nLIGHT LIGHTING CONTROL PANEL	1	TLS	GC	ACUTY	ARP INTENC08 NLT 8SPR MVOLT FM DTC	8 RELAY PANEL FOR DIMMING CONTROL WITH FLUSH MOUNT ENCLOSURE, AND DIGITAL TIME CLOCK
\$C	WALL-MOUNTED OVERRIDE SWITCH (4 CHANNEL)	1	TLS	GC	ACUTY	nPODMA 4P WH	SEE LIGHTING CONTROL DIAGRAM FOR SWITCH CONFIGURATION
\$D	WALL-MOUNTED DIMMER SWITCH	2	TLS	GC	COOPER	SAL06P-W	SLIDE DIMMER COMPATIBLE WITH UP TO 300W LED LIGHTING. SET AT 50%. IF DINING ROOM LIGHTS FLICKER AT THIS DIMMER SETTING THEN GC SHALL PROVIDE LUTRON DVCL-253P DIMMER AS REPLACEMENT.
\$OC	WALL-MOUNTED LINE VOLTAGE OCCUPANCY SENSOR	3	TLS	GC	HUBBELL	LHMTS 1-N-WH	WHITE DUAL TECHNOLOGY SINGLE RELAY WITH 1 BUTTON AND NEUTRAL WIRING

LIGHTING FIXTURE SCHEDULE


TAG	QUANTITY	TYPE	MOUNT	FURNISHED BY	INSTALLED BY	MANUFACTURER	MODEL	LAMP(S)	VOLTS	WATTS	SPECIAL REQUIREMENTS
A1	11	2x2 LED LENSED TROFFER	LAY-IN	TLS	GC	NORA LIGHTING	NPDBL-E22/334 W	(1) 3000K LED	120	30	COMPATIBLE WITH 0-10V DIMMING, FACTORY LOCKED TO 3000K
B1	8	RECESSED 6IN CAN LIGHT	CEILING	TLS	GC	NORA LIGHTING	NHIC-6G24ATFL with NTM-S7W/M1 Trim	(1) 17W ECOSTORY ECO-PAR38C-17-GU24-27K-25D LED (25"-2700K) W/ GU 24 BASE	120	17	
B2	36	RECESSED 6IN CAN LIGHT W/ LED TRIM	CEILING	TLS	GC	NORA LIGHTING	NHIC-6G24ATFL WITH NLCBC-6S130WW LED TRIM	INTEGRAL 3000K LED	120	17	LED TRIM FURNISHED WITH GU24 SOCKET ADAPTER
B3	4	RECESSED 6IN CAN LIGHT W/ BLACK LED TRIM	CEILING	TLS	GC	NORA LIGHTING	NHIC-6G24ATFL WITH NLCBC2-6S127BB LED TRIM	INTEGRAL 3000K LED	120	12	BLACK LED TRIM FURNISHED WITH GU24 SOCKET ADAPTER
C0	2	LOW PROFILE LED - 1 FT	SURFACE	TLS	GC	HERA LIGHTING	EL/LED/12/WW	INTEGRAL 3000K LED	120	5	FURNISHED WITH COVERS, CONNECTORS, AND ONE HARDWIRE BOX OR CORD/PLUG PER SECTION
C2	6	LOW PROFILE LED - 3 FT	SURFACE	TLS	GC	HERA LIGHTING	EL/LED/34/WW	INTEGRAL 3000K LED	120	12	FURNISHED WITH COVERS, CONNECTORS, AND ONE HARDWIRE BOX OR CORD/PLUG PER SECTION
C3	6	LOW PROFILE LED - 4 FT	SURFACE	TLS	GC	HERA LIGHTING	EL/LED/46/WW	INTEGRAL 3000K LED	120	15	FURNISHED WITH COVERS, CONNECTORS, AND ONE HARDWIRE BOX OR CORD/PLUG PER SECTION
C4	8	LOW PROFILE LED - 5 FT	SURFACE	TLS	GC	HERA LIGHTING	EL/LED/59/WW	INTEGRAL 3000K LED	120	18	FURNISHED WITH COVERS, CONNECTORS, AND ONE HARDWIRE BOX OR CORD/PLUG PER SECTION
E1	3	EMERGENCY LIGHT - DUAL HEAD	VARIOUS	TLS	GC	EXITRONIX	LED-90	(2) SPECIAL LED	120	2	90 MINUTE BATTERY BACKUP
E2	3	EXTERIOR REMOTE EMERGENCY LIGHT	VARIOUS	TLS	GC	EXITRONIX	MLED1-B-WP	(1) SPECIAL LED	4	1	LOW VOLTAGE REMOTE EMERGENCY LIGHT POWERED BY REMOTE-CAPABLE EXIT SIGN WITH MOUNTING PLATE
E4	5	WHITE EXIT SIGN WITH EMERGENCY LIGHT - STANDARD RED LETTERS	VARIOUS	TLS	GC	EXITRONIX	CLED-U-WH	(1) SPECIAL LED	120	2	90 MINUTE BATTERY BACKUP WITH INTEGRAL EMERGENCY LIGHT, REMOTE HEAD CAPABLE
E7	8	EMERGENCY LIGHT	VARIOUS	TLS	GC	DUAL-LITE	EV2	(2) 1W INTEGRAL LED	120	1	90 MINUTE BATTERY BACKUP
H1	8	HOOD LIGHT	SURFACE	THS/TLS	THS	VAPOR PROOF LIGHT FIXTURE FURNISHED WITH HOOD		(1) TCP L16A19N1527K	120	23	INSTALL LAMP FURNISHED SEPARATELY BY LIGHTING SUPPLIER
J4	2	DECORATIVE PENDANT	SURFACE	TLS	GC	BARNLIGHT	BLE-C-CPT10-ASH-100-SBK-100-CAW	GREEN CREATIVE 9A19DIM/927/GU24/R	120	9	WITH BLACK LAMP SHADE, BLACK CORD, AND OAK LAMP HOLDER
P5	3	PENDANT	SURFACE	TLS	GC	HI-LITE MFG	H-LC-91/CB12-91/20W LBL	TCP FG25D4027CCQ	120	5	ADJUST CORD LENGTH FOR MOUNTING HEIGHT CALLED FOR IN ARCHITECTURAL DRAWINGS
P6	1	DECORATIVE DINING ROOM PENDANT	SURFACE	TLS	GC	BARN LIGHT	BLE-C-JGT-133-35630-3	INTEGRAL LED	120	30	HARDWIRED SET OF (3) HEADS WITH UNIVERSAL CANOPY AND STANDARD BLACK CABLES
S1	1	DRIVE-UP PICK-UP WINDOW CHIME/STROBE	WALL	TLS	GC	FEDERAL SIGNAL	SLM500B W/ SLMBW-012-024	INTEGRAL	16	0	SET SWITCH A TO "CHIME 1 SINGLE" (11011) AND SWITCH B TO "CHIME 2 SINGLE" (00111)
T1	14	TRACK HEAD	TRACK	TLS	GC	JUNO	R605L 30K 90CRI PDIM WFL BL	INTEGRAL LED	120	10	BLACK CYLINDER TRACK HEAD W/ UNIVERSAL 120V TRAC ADAPTER AND WIDE FLOOD BEAM
T-6	2	TRACK (6 FEET)	SURFACE	TLS	GC	JUNO	T 6FT BK	N/A	120	0	SINGLE CIRCUIT, BLACK FINISH
T-8	2	TRACK (8 FEET)	SURFACE	TLS	GC	JUNO	T 8FT BK	N/A	120	0	SINGLE CIRCUIT, BLACK FINISH
TCL-0.5	2	CURRENT LIMITER (60W)	SURFACE	TLS	GC	JUNO	TCLFM11 BL W/ TCLCB 0.5A BLCK	N/A	120	0	BLACK CURRENT LIMITING END FEED
TCL-1	1	CURRENT LIMITER (120W)	SURFACE	TLS	GC	JUNO	TCLFM11 BL W/ TCLCB 1A BLCK	N/A	120	0	BLACK CURRENT LIMITING END FEED
W1	4	WIC LED FIXTURE	SURFACE	WCS	GC	FURNISHED WITH WIC		INTEGRAL LED	120	29	WET-RATED COOLER FIXTURE
X6	3	EXTERIOR FLOOD LIGHT	SURFACE	TLS	GC	RAB LIGHTING	WPLED10Y	INTEGRAL LED	120	10	PROVIDE WITH WALL-MOUNT KIT.
X9	2	LED CHANNEL LIGHT	SURFACE	EXT'G	EXT'G	PARADIGM LED	AMC-2410-S W/ OPAL LENS AND END CAPS	FLEXSR-45-30-67-24	120	45	FURNISHED W/ REMOTE-MOUNTED NEMA 3R LED DRIVER. SEE PLAN FOR LENGTHS.

LIGHTING FIXTURE SCHEDULE NOTES

- A. FLUORESCENT LAMPS NOT INCLUDED WITH THE FIXTURE AREA TO BE MANUFACTURED BY SYLVANIA UNLESS OTHERWISE NOTED. PHILIPS FLUORESCENT LAMPS WILL BE AN ACCEPTABLE ALTERNATE.
- B. SEE THE ARCHITECTURAL REFLECTED CEILING PLAN FOR EXACT LIGHT LOCATIONS.
- C. SEE THE ARCHITECTURAL LIGHTING DETAILS FOR FIXTURE CONSTRUCTION DETAILS.

ELECTRICAL LIGHTING PLAN NOTES

- INSTALL WALL-MOUNTED LIGHTING OVERRIDE SWITCH AND CONNECT TO LCP AS SHOWN IN DETAIL 6/E710
- FOR UNCIRCUITED LIGHT FIXTURES, CONNECT TO RELAY CIRCUIT INDICATED NEXT TO THE FIXTURE TAG THROUGH THE LIGHTING CONTROL PANEL (LCP) UNLESS NOTED OTHERWISE.
- WALL MOUNT THE EMERGENCY LIGHT FIXTURE AT 6" BELOW THE CEILING UNLESS NOTED OTHERWISE
- VERIFY MOUNTING HEIGHT OF EXIT SIGN PRIOR TO ROUGH IN. EXIT SIGN MUST BE VISIBLE FROM AREA SERVED AFTER BUILDING SYSTEMS HAVE BEEN INSTALLED. SEE ARCHITECTURAL ELEVATIONS FOR FURTHER INFORMATION.
- RELOCATE LED DRIVERS FURNISHED WITH THE X9 LED STRIP LIGHTS ON WALL 6" ABOVE THE CEILING IN AN ACCESSIBLE LOCATION. PROVIDE LOW VOLTAGE WIRING FROM LED DRIVER TO THE X9 LIGHT FIXTURES AS SHOWN.
- INSTALL LIGHT FIXTURES FURNISHED WITH THE WALK-IN COOLER. PROVIDE UNSWITCHED CONDUCTOR FROM LIGHTING CIRCUIT TO WALK-IN COOLER LIGHTING J-BOX AND FROM J-BOX TO LIGHT FIXTURES AS SHOWN. CONDUIT BETWEEN LIGHT FIXTURES SHALL BE ROUTED ON THE INTERIOR OF THE WALK-IN COOLER. SEAL INTERIOR AND EXTERIOR OF CONDUITS WHERE THEY PASS THROUGH THE WALK-IN COOLER ENVELOPE PER THE NEC.
- PROVIDE (2) GFCI RECEPTACLES FOR UNDERSHELF LIGHTING AS SHOWN. CONNECT TO SWITCHED LEG OF THE KITCHEN LIGHTING CIRCUIT. SEE ELEVATIONS ON SHEET E700 FOR RECEPTACLE LOCATIONS, HEIGHTS, AND CIRCUITING. INSTALL RECEPTACLES IN A HORIZONTAL ORIENTATION.
- PROVIDE UNISTRUT AS SHOWN ON THE ARCHITECTURAL RCP PER THE ARCHITECTURAL UNISTRUT DETAIL. TYPICAL.
- CONNECT EXTERIOR LIGHTING CIRCUIT TO CIRCUIT SHOWN THROUGH THE EXTERIOR LIGHTING CONTACTOR PANEL PER DETAIL 6/E710.
- INSTALL WALL-MOUNTED OCCUPANCY SENSOR FURNISHED BY LIGHTING SUPPLIER AT 42" AFF. ADJUST OCCUPANCY SENSOR TO PROVIDE AUTOMATIC ON/AUTOMATIC OFF OPERATION WITH A FIXED TIMER OF 30 MINUTES AND WITH BOTH THE PASSIVE INFRARED AND ULTRASONIC SENSORS ENABLED.
- INSTALL CHIME/STROBE FURNISHED WITH VEHICLE DETECTION SYSTEM ON WALL 12" BELOW CEILING AND CONNECT TO VEHICLE DETECTOR SYSTEM PER THE MANUFACTURER'S INSTALLATION INSTRUCTIONS.
- INSTALL WALL-MOUNTED DIMMERS ABOVE PANELBOARDS 6" ABOVE LAY-IN CEILING FOR CONTROL OF DINING ROOM OVERHEAD STRIP LED LIGHTS. CONNECT DIMMERS TO RELAYS SHOWN THROUGH THE LIGHTING CONTROL PANEL. SET DIMMERS AT 50%.
- CONNECT DINING ROOM (RELAY CIRCUITS R4 & R5) OVERHEAD STRIP LED LIGHTS TO THE RELAY INDICATED THROUGH THE CORRESPONDING WALL-MOUNTED DIMMER INSTALLED ABOVE THE PANELBOARDS.
- INSTALL LIGHTING CONTROL SYSTEM PER DETAIL 6/E710.
- INSTALL E2 REMOTE EMERGENCY LIGHT TO BOTTOM OF CANOPY. CONCEAL LOW VOLTAGE WIRING FROM EXIT SIGN TO REMOTE EMERGENCY LIGHT.

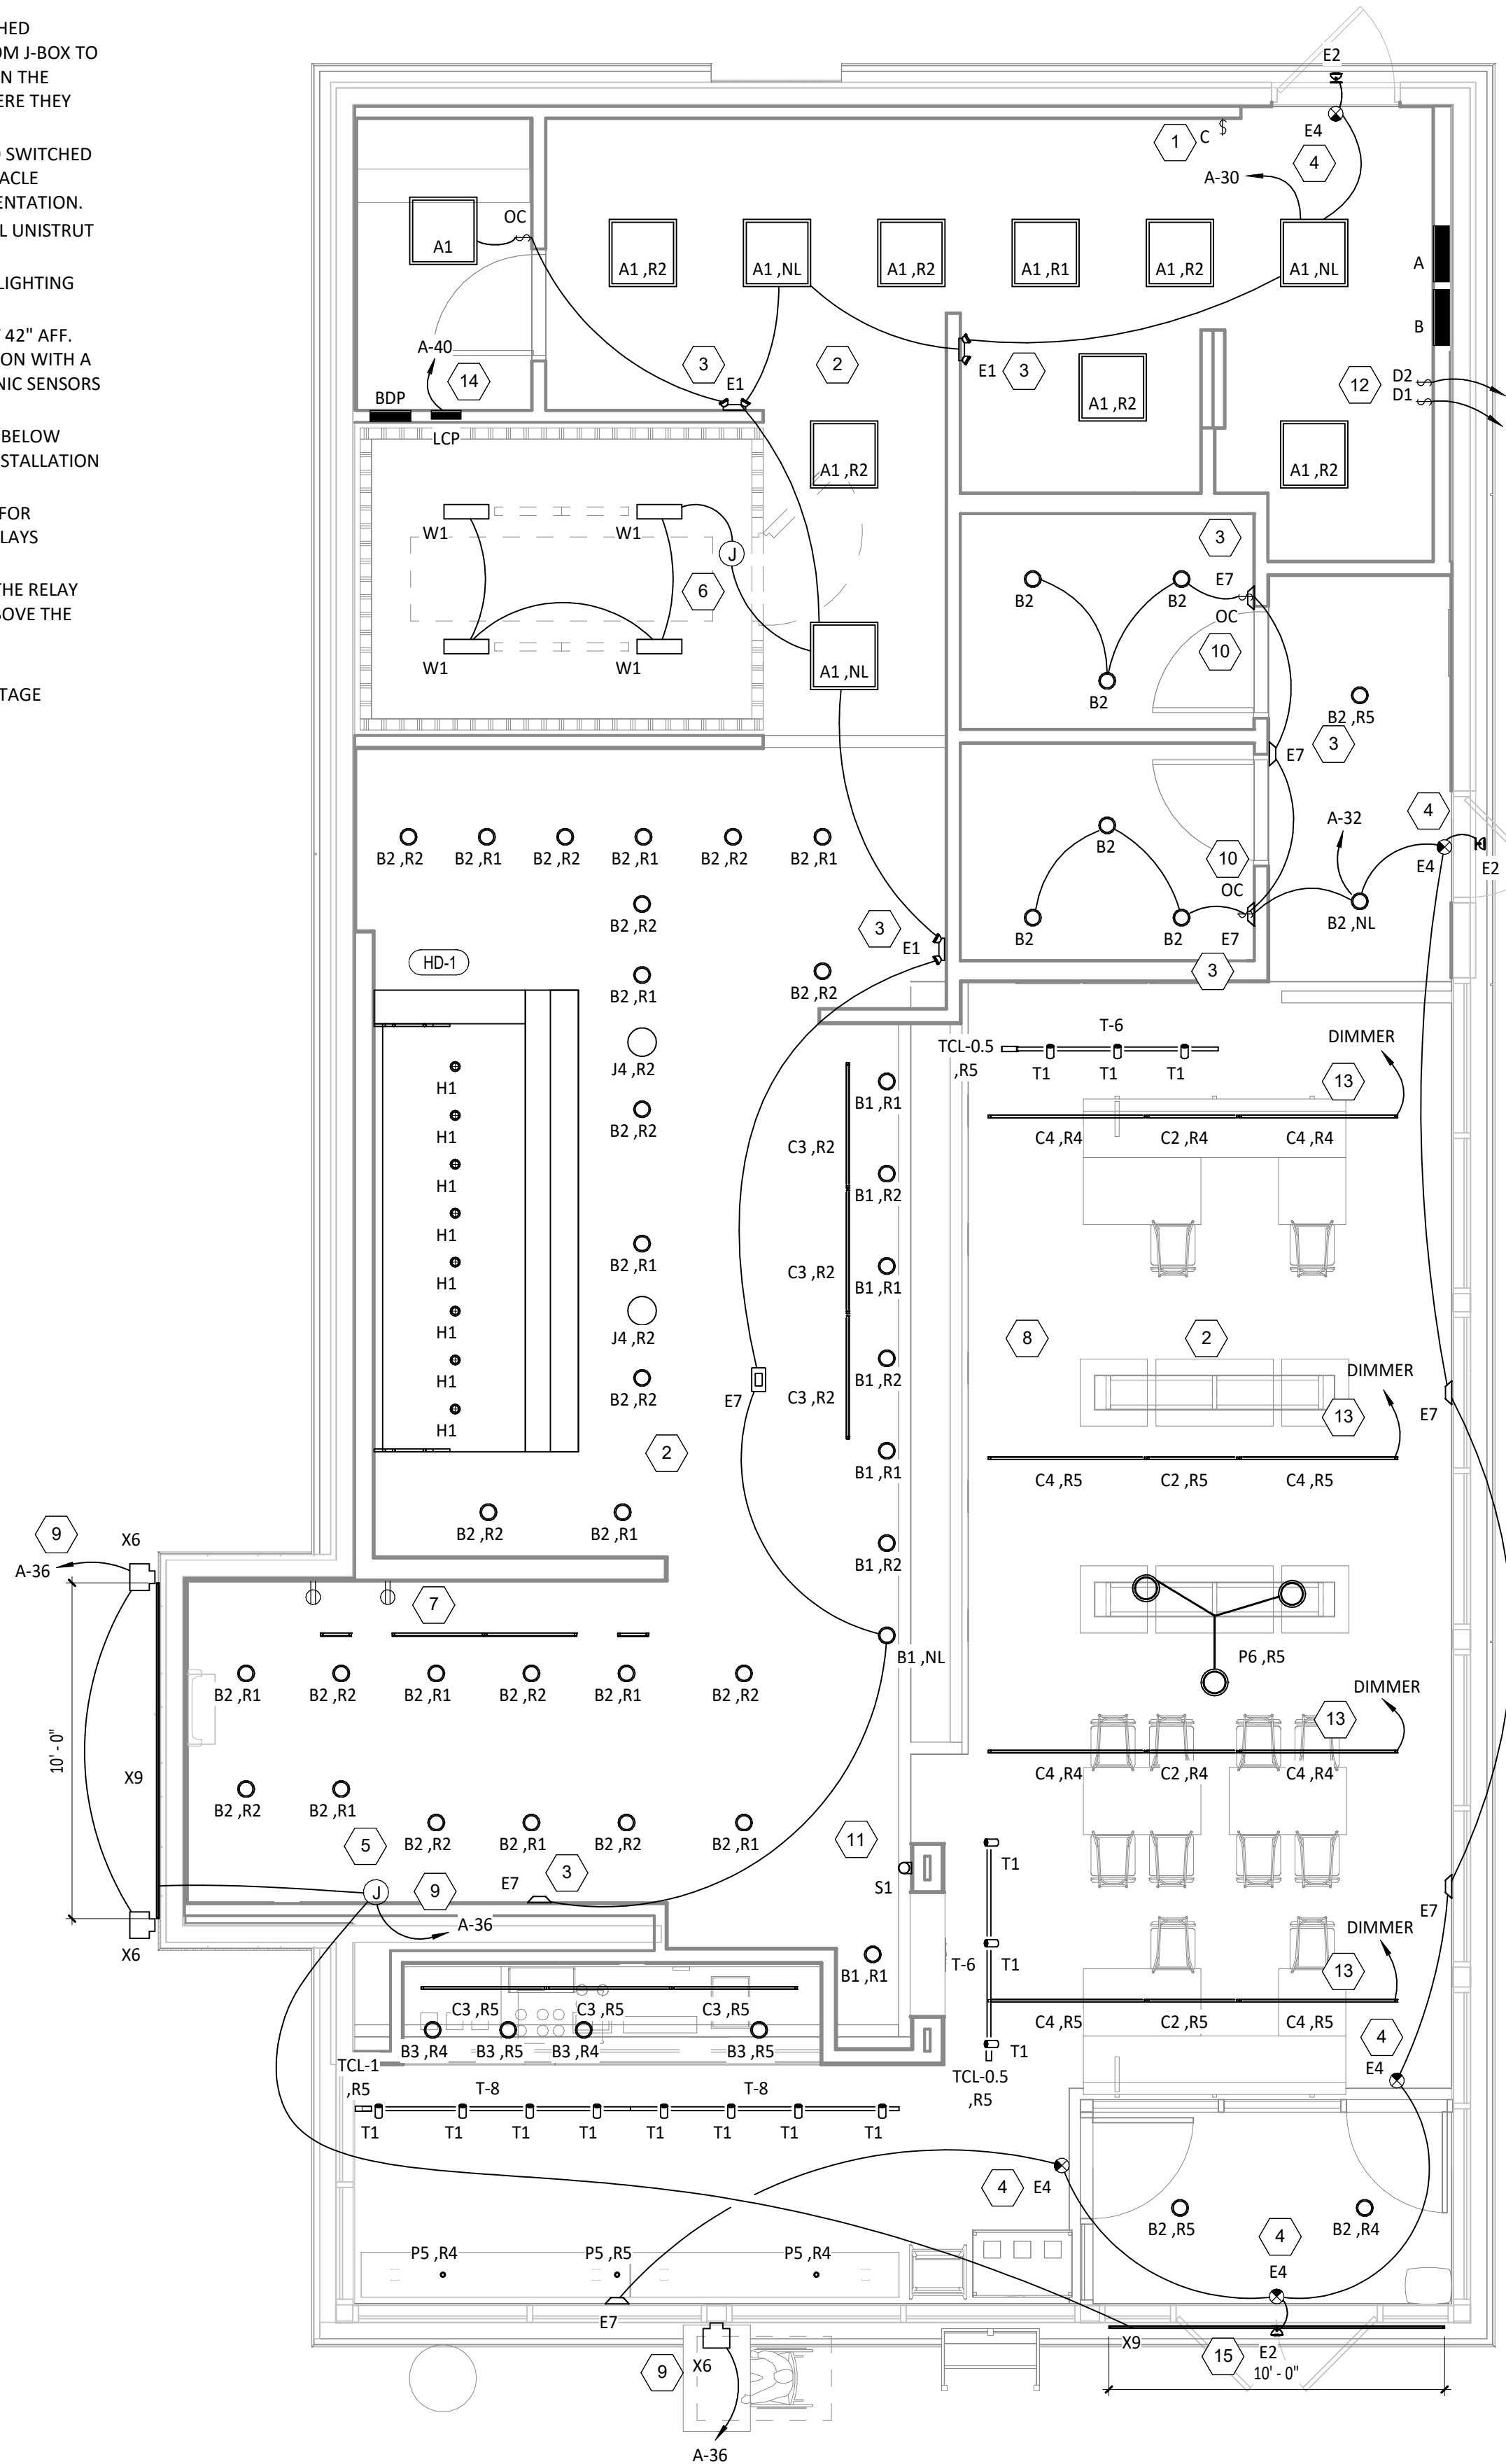LIGHTING FLOOR PLAN
1/4" = 1'-0"

Consultant:



4635 Trueman Blvd, Suite 250
Hilliard, Ohio 43026
Phone: (614) 751-9610
Fax: (614) 552-5240
Contact: Cliff Kigar
(614) 328-2033
ckigar@nationalengineering.com

FOR CONSTRUCTION

COPYRIGHT 2024
THIS DRAWING IS AN INSTRUMENT OF SERVICE
AND AS SUCH REMAINS THE PROPERTY OF
CHIPOTLE MEXICAN GRILL, INC.. PERMISSION FOR
USE OF THIS DOCUMENT IS LIMITED AND CAN BE
EXTENDED ONLY BY WRITTEN AGREEMENT WITH
CHIPOTLE MEXICAN GRILL, INC..



CHIPOTLE MEXICAN GRILL, INC.
PO BOX 182566
COLUMBUS, OH 43218-2566
TELEPHONE: (614) 318-2400
INTERNET: WWW.CHIPOTLE.COM

STORE NO.: 4757

ANDERSON
S SCATTERFIELD RD
ANDERSON, IN 46013

Issue Record:

12/12/2023

05/20/2024

07/24/2024

PERMIT SET

BID SET

CONSTRUCTION SET

Revisions:

Drawn:

Checked:

DVB/CJK/JEJ

JEJ

Project No.

2201198

Contents:

ELECTRICAL
LIGHTING PLAN


E100

ELECTRICAL POWER PLAN NOTES


- 1 SHOW ROOM WINDOW RECEPTACLE. COORDINATE EXACT RECEPTACLE MOUNTING HEIGHT IN THE FIELD. LOCATION SHALL BE IN THE DRYWALL IMMEDIATELY ABOVE THE MAIN STORE-FRONT WINDOW AND AS SHOWN IN THE DINING ROOM ELECTRICAL ELEVATIONS ON SHEET E700.
- 2 ICE MACHINE ELECTRICAL TIE-IN. COORDINATE EXACT LOCATION WITH EQUIPMENT INSTALLER PRIOR TO ROUGH-IN. PROVIDE L5-20P FLANGED INLET WIRED TO THE REMOTE CONDENSER. PROVIDE 48" CORDS, ONE WITH 5-20P END AND ONE WITH L5-20R END, FROM ICE MAKER TO RECEPTACLE AND FLANGED INLET.
- 3 CONNECT RECEPTACLES SERVING EQUIPMENT BELOW THE KITCHEN HOOD TO THE CIRCUITS SHOWN THROUGH THE CONTACTOR INTEGRAL TO THE HOOD CONTROL PANEL. INTEGRAL CONTACTOR SHALL BE INTERLOCKED TO HOOD FIRE PROTECTION SYSTEM SO THAT RECEPTACLES ARE DE-ENERGIZED UPON ACTIVATION OF HOOD FIRE PROTECTION SYSTEM.
- 4 JUNCTION BOX FOR EXTERIOR SIGN LIGHTING. COORDINATE EXACT LOCATION WITH CHIPOTLE'S CONSTRUCTION MANAGER AND THE SIGN INSTALLER PRIOR TO ROUGH-IN. CONNECT TO CIRCUIT SHOWN THROUGH THE EXTERIOR LIGHTING CONTACTOR PANEL AS SHOWN IN DETAIL 6/E710.
- 5 PROVIDE A SINGLE GANG VERTICAL JUNCTION BOX FOR THE KITCHEN EXHAUST SUPPRESSION SYSTEM PULL STATION. PROVIDE A 1/2" CONDUIT FROM THE J-BOX TO 6" ABOVE THE CEILING AND TERMINATE WITH A CONDUIT BUSHING. COORDINATE EXACT LOCATION WITH THE KITCHEN EXHAUST SUPPRESSION SYSTEM INSTALLER AND THE FIRE MARSHALL PRIOR TO ROUGH-IN.
- 6 HOOD CONTROL PANEL AND KITCHEN EXHAUST SUPPRESSION SYSTEM CABINET SHALL BE LOCATED WITHIN THE INTEGRAL HOOD UTILITY CABINET. PROVIDE FINAL ELECTRICAL CONNECTIONS PER THE MANUFACTURER'S INSTALLATION INSTRUCTIONS NECESSARY FOR A COMPLETE AND OPERATIONAL SYSTEM.
- 7 PROVIDE A DUPLEX GFCI RECEPTACLE WITH WEATHERPROOF WHILE IN USE OUTLET COVER FOR IRRIGATION CONTROLLER.
- 8 PROVIDE AN EMPTY SINGLE GANG J-BOX FOR VOLUME CONTROLS. INSTALL 16/2 SPEAKER WIRE FURNISHED BY MSS FROM THE J-BOX TO THE AMPIFIER IN THE OFFICE WITH 3 FEET OF SLACK AT EACH END.
- 9 COORDINATE DATA/POWER RECEPTACLE MOUNTING REQUIREMENTS WITH THE CASE WORK INSTALLER PRIOR TO ROUGH-IN.
- 10 PROVIDE ROUGH-IN FOR LAUNCHPORT AS NOTED. LAUNCHPORT WILL BE FURNISHED AND INSTALLED BY CHIPOTLE WITH THE WALLSTATION AT 62" AFF. PROVIDE A 4" X 2-1/8" DEEP OCTAGON J-BOX WITH 1-1/2" EXTENSION RING AT 62" AFF FOR THE WALLSTATION INSTALLATION WITH A 1" CONDUIT WITH PULL STRING FROM THE J-BOX TO ABOVE THE OFFICE CEILING.
- 11 PROVIDE AN EMPTY 1" CONDUIT WITH PULL STRING FROM THE BASE BUILDING'S TELEPHONE SERVICE ENTRANCE LOCATION TO THE SPACE ABOVE THE OFFICE CEILING.
- 12 PROVIDE A SUITABLE LENGTH OF LIQUID-TIGHT CONDUIT TO THE EXHAUST FAN EF-1 TO ALLOW THE EXHAUST FAN TO HINGE COMPLETELY OPEN WHEN THE VIROGUARD SYSTEM IS INSTALLED.
- 13 AFTER THE FAX LINE, POS, AND OFFICE EQUIPMENT IS INSTALLED PROVIDE CHILDPROOF RECEPTACLE COVERS ON UNUSED IG RECEPTACLES AT THE FAX LINE, POS, AND OFFICE.
- 14 PROVIDE ONE PHASE, ONE NEUTRAL, AND ONE GROUND CONDUCTOR FROM THE ICE MAKER TO THE REMOTE CONDENSING UNIT.
- 15 UNIT SHALL HAVE AN INTEGRAL NON-FUSED DISCONNECT SWITCH.
- 16 PROVIDE 3" CONDUIT (EMT, IMC, OR RMC) THROUGH ROOF. TERMINATE WITH WEATHERHEAD 12" ABOVE ROOF FOR FUTURE CELL BOOSTER.
- 17 INSTALL THE BYPASS DISTRIBUTION PANEL (BDP) FURNISHED BY THE TENANT. INSTALL PER THE MANUFACTURER'S INSTALLATION INSTRUCTIONS AND DETAIL 3/E710.
- 18 ROUGH-INS TO SERVE LINE AND POS EQUIPMENT ARE UNDERGROUND. COORDINATE ROUGH-IN REQUIREMENTS AND LOCATIONS WITH EQUIPMENT MANUFACTURER PRIOR TO ROUGH-IN.
- 19 ROOFTOP UNIT SHALL HAVE AN INTEGRAL UNIT-MOUNTED GFCI RECEPTACLE. PROVIDE CONNECTION TO CIRCUIT SHOWN.
- 20 ICE MAKER RECEPTACLES SHALL BE CONCEALED BEHIND THE ICE MAKER. COORDINATE LOCATION WITH ACTUAL WIDTH OF ICE MAKER.
- 21 PROVIDE VERTICAL METAL DIE CAST WEATHERPROOF WHILE IN USE OUTLET COVER ON RECEPTACLES AT COOK LINE. COVER SHALL BE INTERMATIC WP1010MXD FOR SINGLE GANG BOXES AND WP1030MXD FOR DOUBLE GANG BOXES. NO SUBSTITUTIONS SHALL BE ACCEPTED.
- 22 LABEL BATTERY-PROTECTED RECEPTACLES "BATTERY-PROTECTED: DISCONNECT AT PANEL BDP".
- 23 LABEL MAIN DISCONNECT SWITCH AND PANEL A "WARNING: BATTERY-PROTECTED RECEPTACLES IN USE. DISCONNECT AT PANEL BDP."

ELECTRICAL POWER PLAN NOTES

- 24 PROVIDE A NEMA 5-20P FLANGED INLET (LEVITON MODEL #15378-C) AND A SINGLE NEMA 5-20R RECEPTACLE IN OFFICE FOR CONNECTION TO A CENTRAL UPS SYSTEM. CONNECT THE FLANGED INLET AND THE SINGLE RECEPTACLE TO THE TERMINAL BLOCK IN THE BDP PER THE MANUFACTURER'S INSTRUCTIONS. PROVIDE FINAL CONNECTION FROM FLANGED INLET TO THE OUTPUT OF THE UPS USING A 2'-LONG 20A EXTENSION CORD. PLUG THE UPS INTO THE SINGLE RECEPTACLE.
- 25 CONNECT RESTROOM EXHAUST FAN TO CIRCUIT SHOWN THROUGH THE LIGHTING CONTROL PANEL (LCP).
- 26 INSTALL 16/2 SPEAKER WIRE FURNISHED BY MSS. INSTALL SPEAKER WIRE BETWEEN SPEAKERS IN THE DINING ROOM AS SHOWN TO THE VOLUME CONTROL IN THE KITCHEN WITH 3 FEET OF SLACK AT EACH END. SEE ARCHITECTURAL PLANS FOR SPEAKER LOCATIONS. ADJUST EACH SPEAKER 70V TAP SETTING TO BE 15 WATTS.
- 27 PROVIDE POWER CONNECTIONS TO ISLAND PREP TABLE PER DETAIL 2/E710. PROVIDE GFCI DUPLEX RECEPTACLES IN THREE J-BOXES INTEGRAL TO PREP TABLES (FOR UNDERCOUNTER REFRIGERATOR, HOT HOLDING CABINET, AND GENERAL RECEPTACLE).
- 28 PROVIDE GFCI RECEPTACLE AND J-BOX AND INSTALL CO2 ALARM FURNISHED BY CO2AS AS SHOWN IN DETAIL 4/E710.
- 29 PROVIDE J-BOX AND INSTALL CO2 ALARM REMOTE DISPLAY UNIT FURNISHED BY CO2AS AS SHOWN IN DETAIL 4/E710.
- 30 INSTALL WALK-IN-COOLER EXTERNAL READOUT THERMOMETER REMOTE PROBE ON WALL OPPOSITE FROM DOOR AS SHOWN. ROUTE TEMPERATURE PROBE WIRE ABOVE WALK-IN COOLER CEILING PANELS, SEAL PENETRATIONS THROUGH THE CEILING PANELS, AND SECURE VERTICAL PROBE WIRE TIGHT TO WALLS. NO EXCESS PROBE WIRE SHALL BE WITHIN THE WALK-IN COOLER.
- 31 PROVIDE RECEPTACLE FOR RESTROOM HAND SINK FAUCET AS SHOWN IN DETAIL 14/P700.
- 32 PROVIDE HORIZONTAL SINGLE-GANG J-BOX FOR DATA JACK AS SHOWN FOR KRONOS TIME CLOCK.
- 33 PROVIDE 1" CONDUITS FROM LOW-VOLTAGE J-BOXES AT POS COUNTER CONCEALED WITHIN THE SERVE LINE WIRING CHASE TO THE WALL, THEN CONCEALED WITHIN THE WALL AND ABOVE THE CEILING TO ABOVE THE OFFICE CEILING.
- 34 PROVIDE A TWO-CONDUCTOR LOW VOLTAGE WIRE IN 3/4" C. AND (4) #12, #12 N., #12 G. IN 1" C. FROM MAU-1 TO THE HOOD CONTROL PANEL PER THE MANUFACTURER'S INSTALLATION INSTRUCTIONS.
- 35 IF NEUTRAL CONDUCTOR IS NOT NEEDED FOR SERVE LINE HOT FOOD SERVER TERMINATE NEUTRAL IN JUNCTION BOX.
- 36 LABEL UTENSIL COUNTER RECEPTACLES "TRACTOR BEVERAGE", "ICE MAKER/IMSB", AND "SODA FOUNTAIN".
- 37 LABEL RECEPTACLE "UV INSECT TRAP".
- 38 INSTALL TRANSFORMER FURNISHED BY TUV WITH THE REME HALO AIR PURIFIER IN THE JUNCTION BOX ON THE EXTERIOR OF THE RTU PER DETAIL 6/M700. CONNECT LINE SIDE OF THE TRANSFORMER TO THE RTU SERVICE RECEPTACLE CIRCUIT SO THAT REME HALO RUNS CONTINUOUSLY. CONNECT THE LOW VOLTAGE SIDE OF THE TRANSFORMER TO THE REME HALO USING THE INCLUDED BARREL PLUG.
- 39 PROVIDE (2) 10"x10"x4" JUNCTION BOXES (J-BOX #1/J-BOX #2) ON THE WALL ABOVE PANELBOARDS 6" BELOW THE LAY-IN CEILING AND MOUNTED ADJACENT TO EACH. PROVIDE CONDUITS AND WIRING SHOWN IN DETAIL 8/E710. TEMS SHALL PROVIDE GRIDPOINT 3 PHASE METER AND TRANSFORMER WITHIN J-BOX #1 AND GRIDPOINT IOM/HUB WITHIN J-BOX #2. SEE GRIDPOINT INSTALLATION SHEET FOR DETAILS.
- 40 PROVIDE HORIZONTAL SINGLE-GANG J-BOX BELOW FUTURE GRIDPOINT CONTROLLER LOCATION. PROVIDE CONDUITS AND WIRING AS SHOWN IN DETAIL 8/E710.
- 41 INSTALL WIRED DOOR BUZZER AT 96" AFF. SEE ARCHITECTURAL DOOR EQUIPMENT FOR EQUIPMENT INFORMATION. CONNECT TO CIRCUIT SHOWN THROUGH THE TRANSFORMER FURNISHED WITH THE DOOR BUZZER. PROVIDE WIRING TO A BUTTON ADJACENT TO THE SERVICE DOOR AND CONNECT PER THE MANUFACTURER'S INSTALLATION INSTRUCTIONS.
- 42 CONNECT BATHROOM SANITIZER TO CIRCUIT SHOWN SO THAT IT IS ENERGIZED AT ALL TIMES.
- 43 PROVIDE POWER AND LOW VOLTAGE CONNECTIONS TO DISH SANITIZING MACHINE PER DETAIL 7/E710. CONNECT THE DETERGENT DISPENSER TO THE DISH MACHINE USING THE INCLUDED WIRING HARNESS PER THE MANUFACTURER'S INSTALLATION INSTRUCTIONS.
- 44 PROVIDE RECEPTACLE FOR 2-DOOR AND/OR 1-DOOR REFRIGERATOR WITH GROUND PINS TOWARDS THE BOTTOM OF THE RECEPTACLE.
- 45 PROVIDE ISLAND PREP TABLE FOOD WARMER RECEPTACLE WITH GROUND PIN TOWARDS THE BOTTOM OF THE RECEPTACLE. SEAL INTERIOR AND EXTERIOR OF CONDUITS THAT PASS THROUGH THE WALK-IN COOLER ENVELOPE PER THE NEC.
- 46 SEAL INTERIOR AND EXTERIOR OF CONDUITS THAT PASS THROUGH THE WALK-IN COOLER ENVELOPE PER THE NEC.
- 47 INSTALL VEHICLE DETECTOR SYSTEM FURNISHED BY TLS SURFACE-MOUNTED ON WALL IN ACCESSIBLE LOCATION ABOVE CEILING AND CONNECT TO STROBE/CHIME AND DETECTOR LOOP PER THE MANUFACTURER'S INSTALLATION INSTRUCTIONS. MAKE FINAL ADJUSTMENTS TO LOOP SENSITIVITY PER THE MANUFACTURER'S INSTRUCTIONS. ONCE ALL COMPONENTS ARE INSTALLED AND OPERATIONAL THE CHIME/STROBE LIGHT SHOULD STAY ILLUMINATED AND THERE SHOULD BE A SINGLE CHIME WHEN A VEHICLE DRIVES OVER OR STOPS ON LOOP.
- 48 PROVIDE CORD AND NEMA 5-20P PLUG FROM UTENSIL COUNTER ICE MAKER, THROUGH UTENSIL COUNTER, TO ICE MAKER RECEPTACLE.
- 49 PROVIDE 4" SQUARE J-BOX ON EXTERIOR WALL FOR MOUNTING OF EXTERIOR CAMERA. SEE ARCHITECTURAL ELEVATION FOR EXACT HEIGHT AND LOCATION. PROVIDE 3/4" CONDUIT WITH PULLSTRING FROM J-BOX TO ABOVE LAY-IN CEILING AREA IN KITCHEN. J-BOX SHALL NOT BE SURFACE MOUNTED. BASE OF CAMERA SHALL BE MOUNTED FLUSH TO EXTERIOR WALL FINISH.

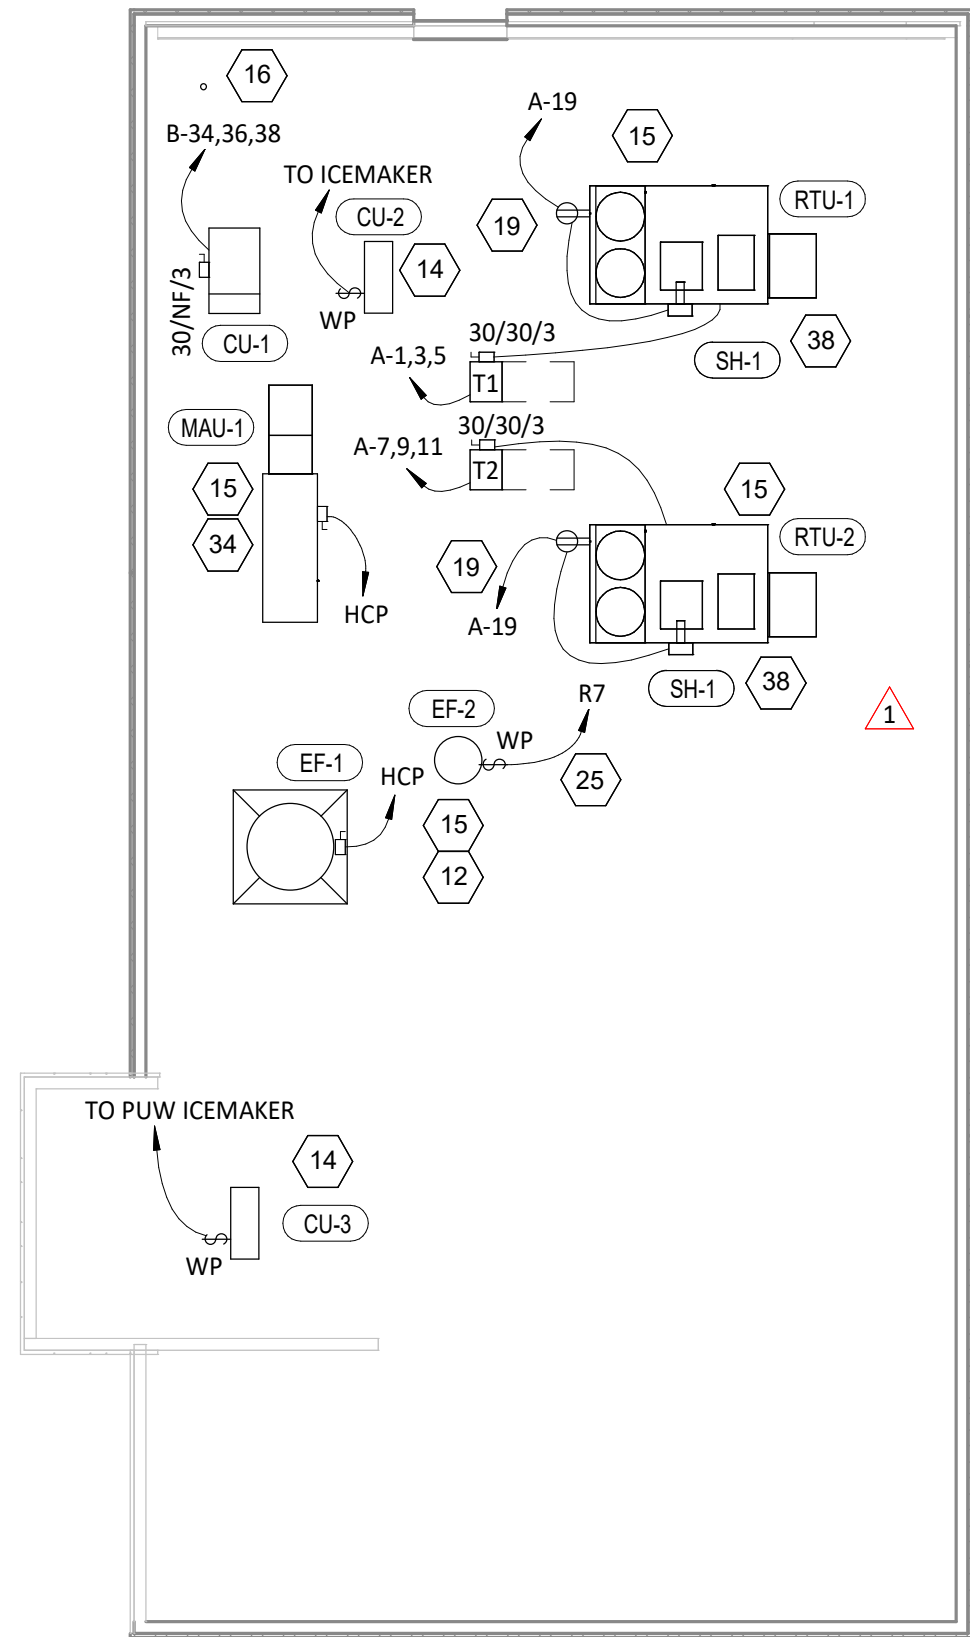


POWER ROOF PLAN
1/8" = 1'-0"

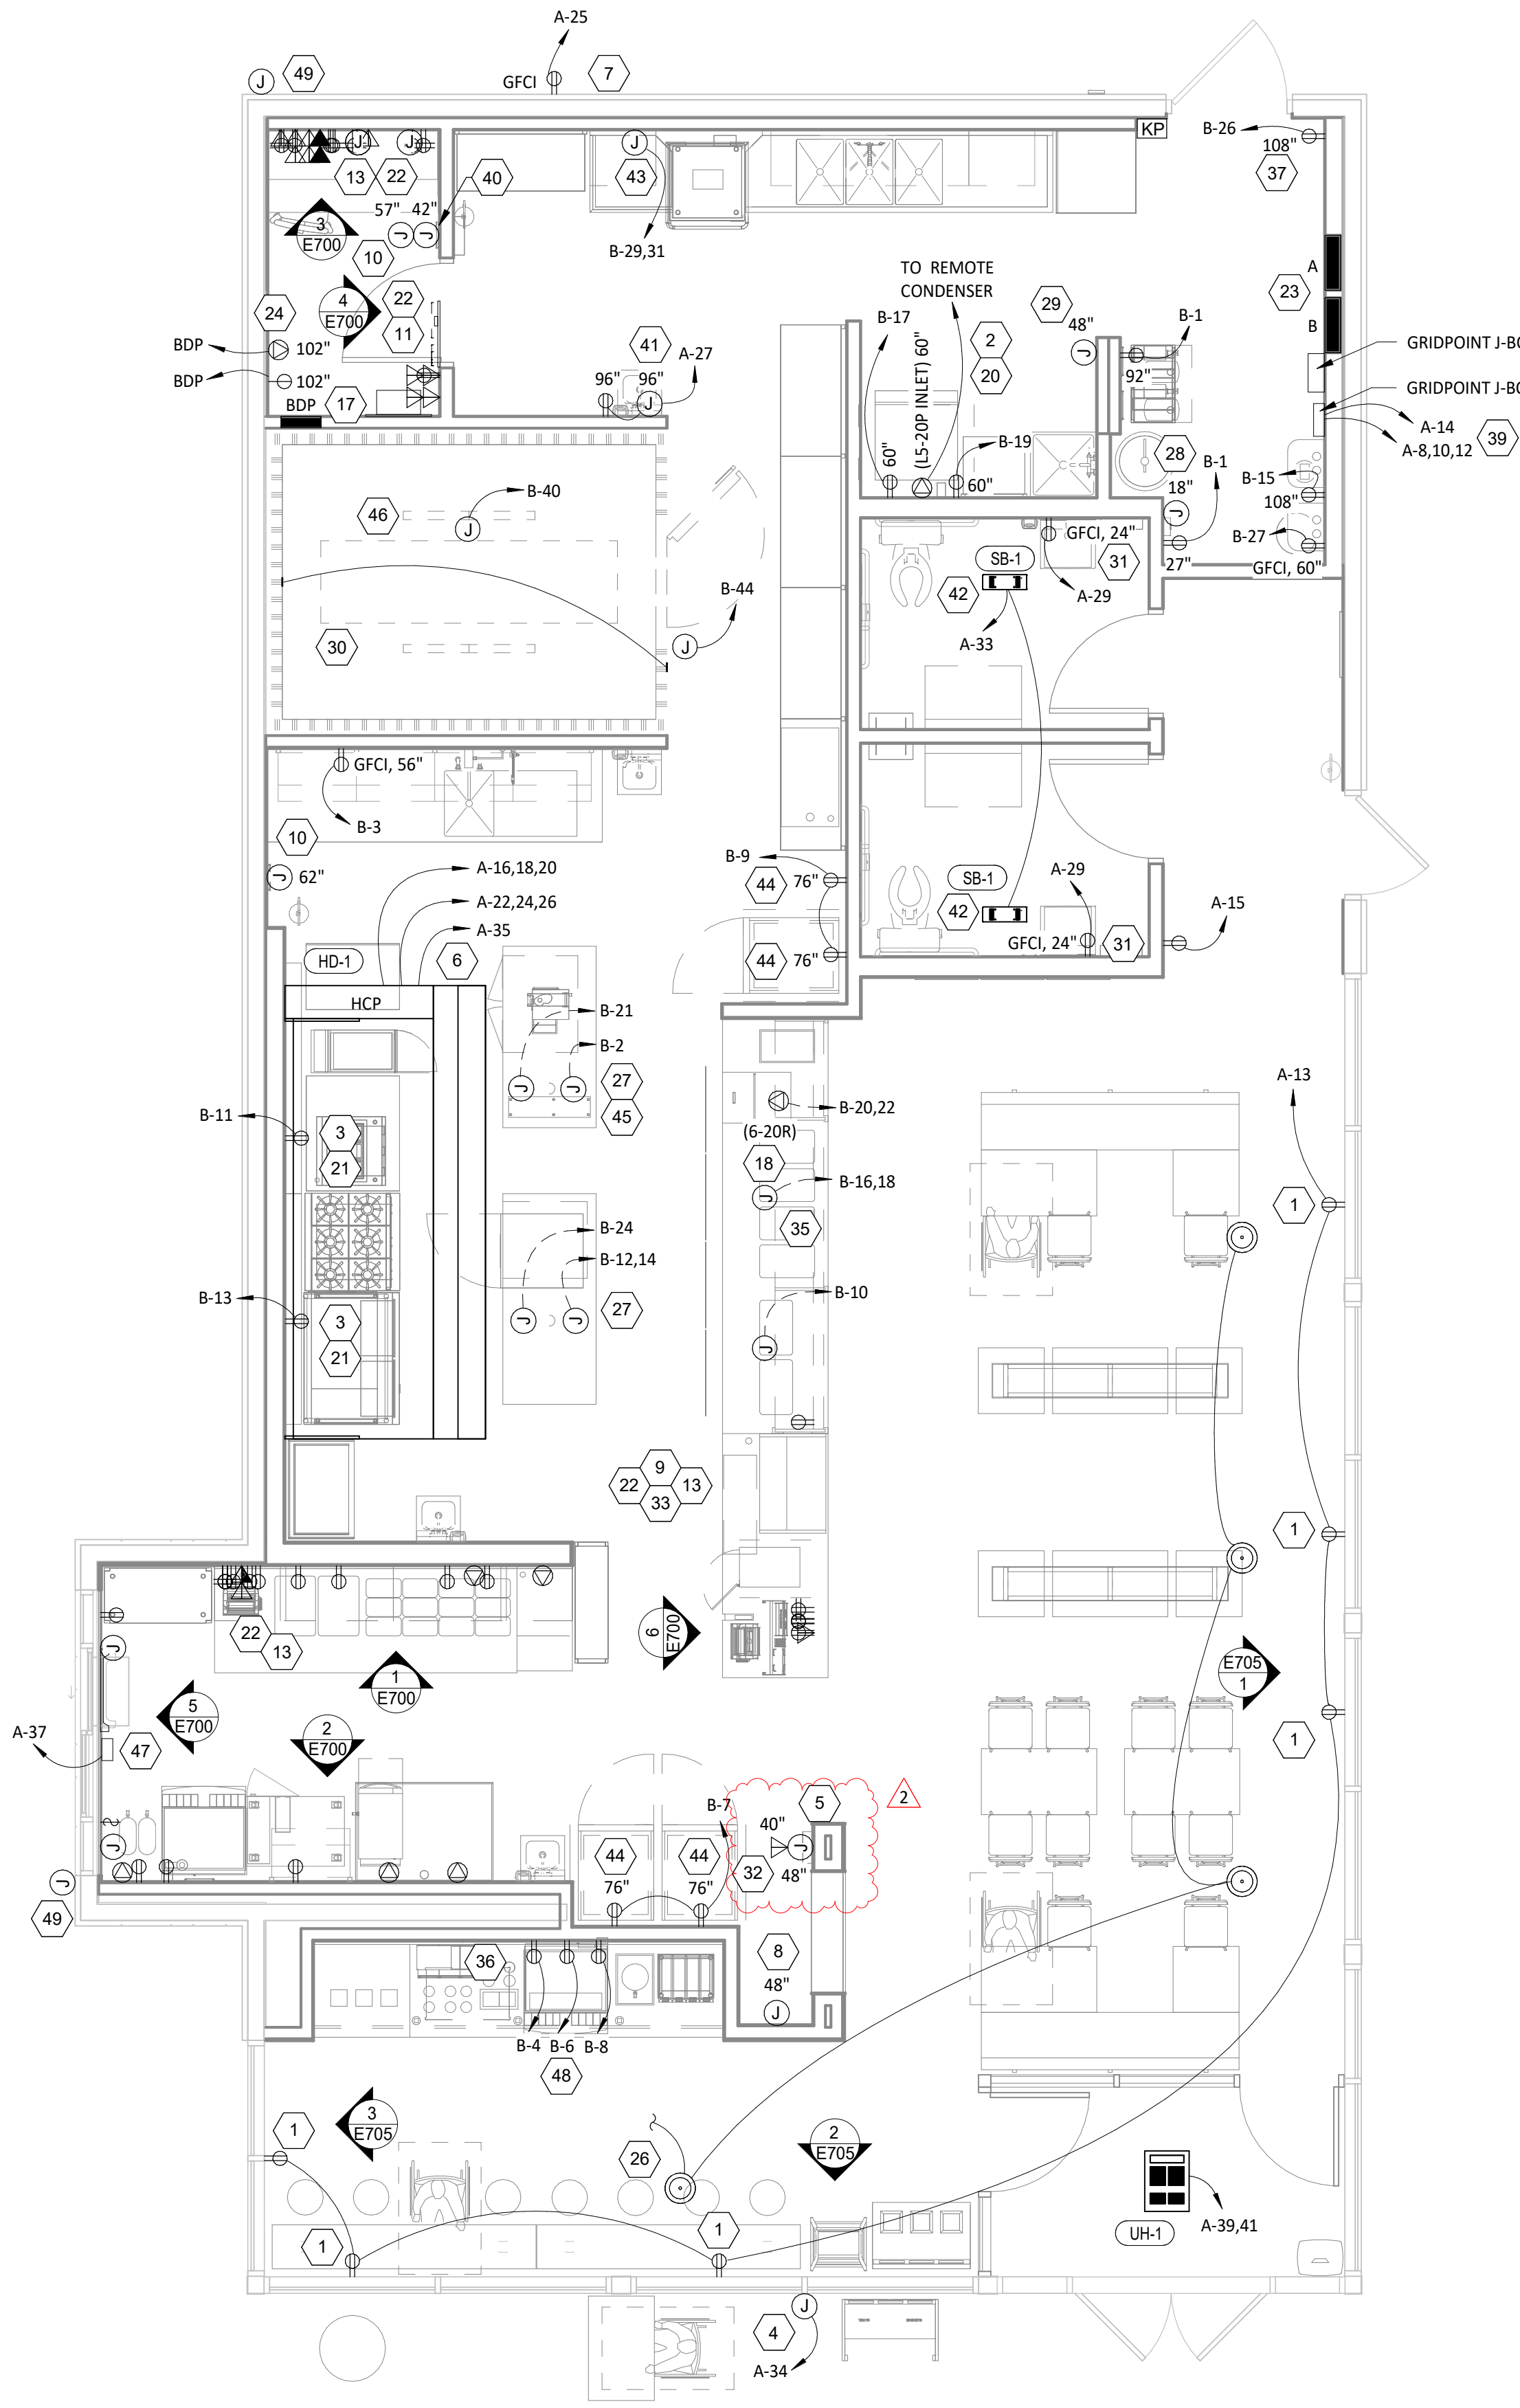

POWER FLOOR PLAN
1/4" = 1'-0"

Consultant:

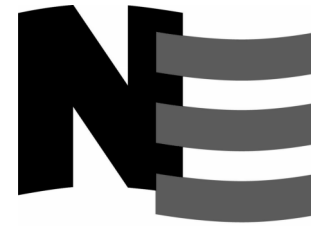

4635 Trueman Blvd. Suite 250
Hilliard, Ohio 43026
Phone: (614) 751-9610
Fax: (614) 552-5240
Contact: Cliff Kigar
(614) 328-2033
ckigar@nationalengineering.com

FOR CONSTRUCTION

COPYRIGHT 2024
THIS DRAWING IS AN INSTRUMENT OF SERVICE
AND AS SUCH REMAINS THE PROPERTY OF
CHIPOTLE MEXICAN GRILL, INC.. PERMISSION FOR
USE OF THIS DOCUMENT IS LIMITED AND CAN BE
EXTENDED ONLY BY WRITTEN AGREEMENT WITH
CHIPOTLE MEXICAN GRILL, INC..



CHIPOTLE MEXICAN GRILL, INC.
PO BOX 182566
COLUMBUS, OH 43218-2566
TELEPHONE: (614) 318-2400
INTERNET: WWW.CHIPOTLE.COM

STORE NO.: 4757
ANDERSON
S SCATTERFIELD RD
ANDERSON, IN 46013

Issue Record:	
12/12/2023	PERMIT SET
05/20/2024	BID SET
07/24/2024	CONSTRUCTION SET

Revisions:	
1	05-20-2024 RTU REVISION
2	07-24-2024 CONSTRUCTION SET



Drawn: DVB/CJK
Checked: JEJ

Project No:
2201198

Contents:

ELECTRICAL POWER
PLAN

E110

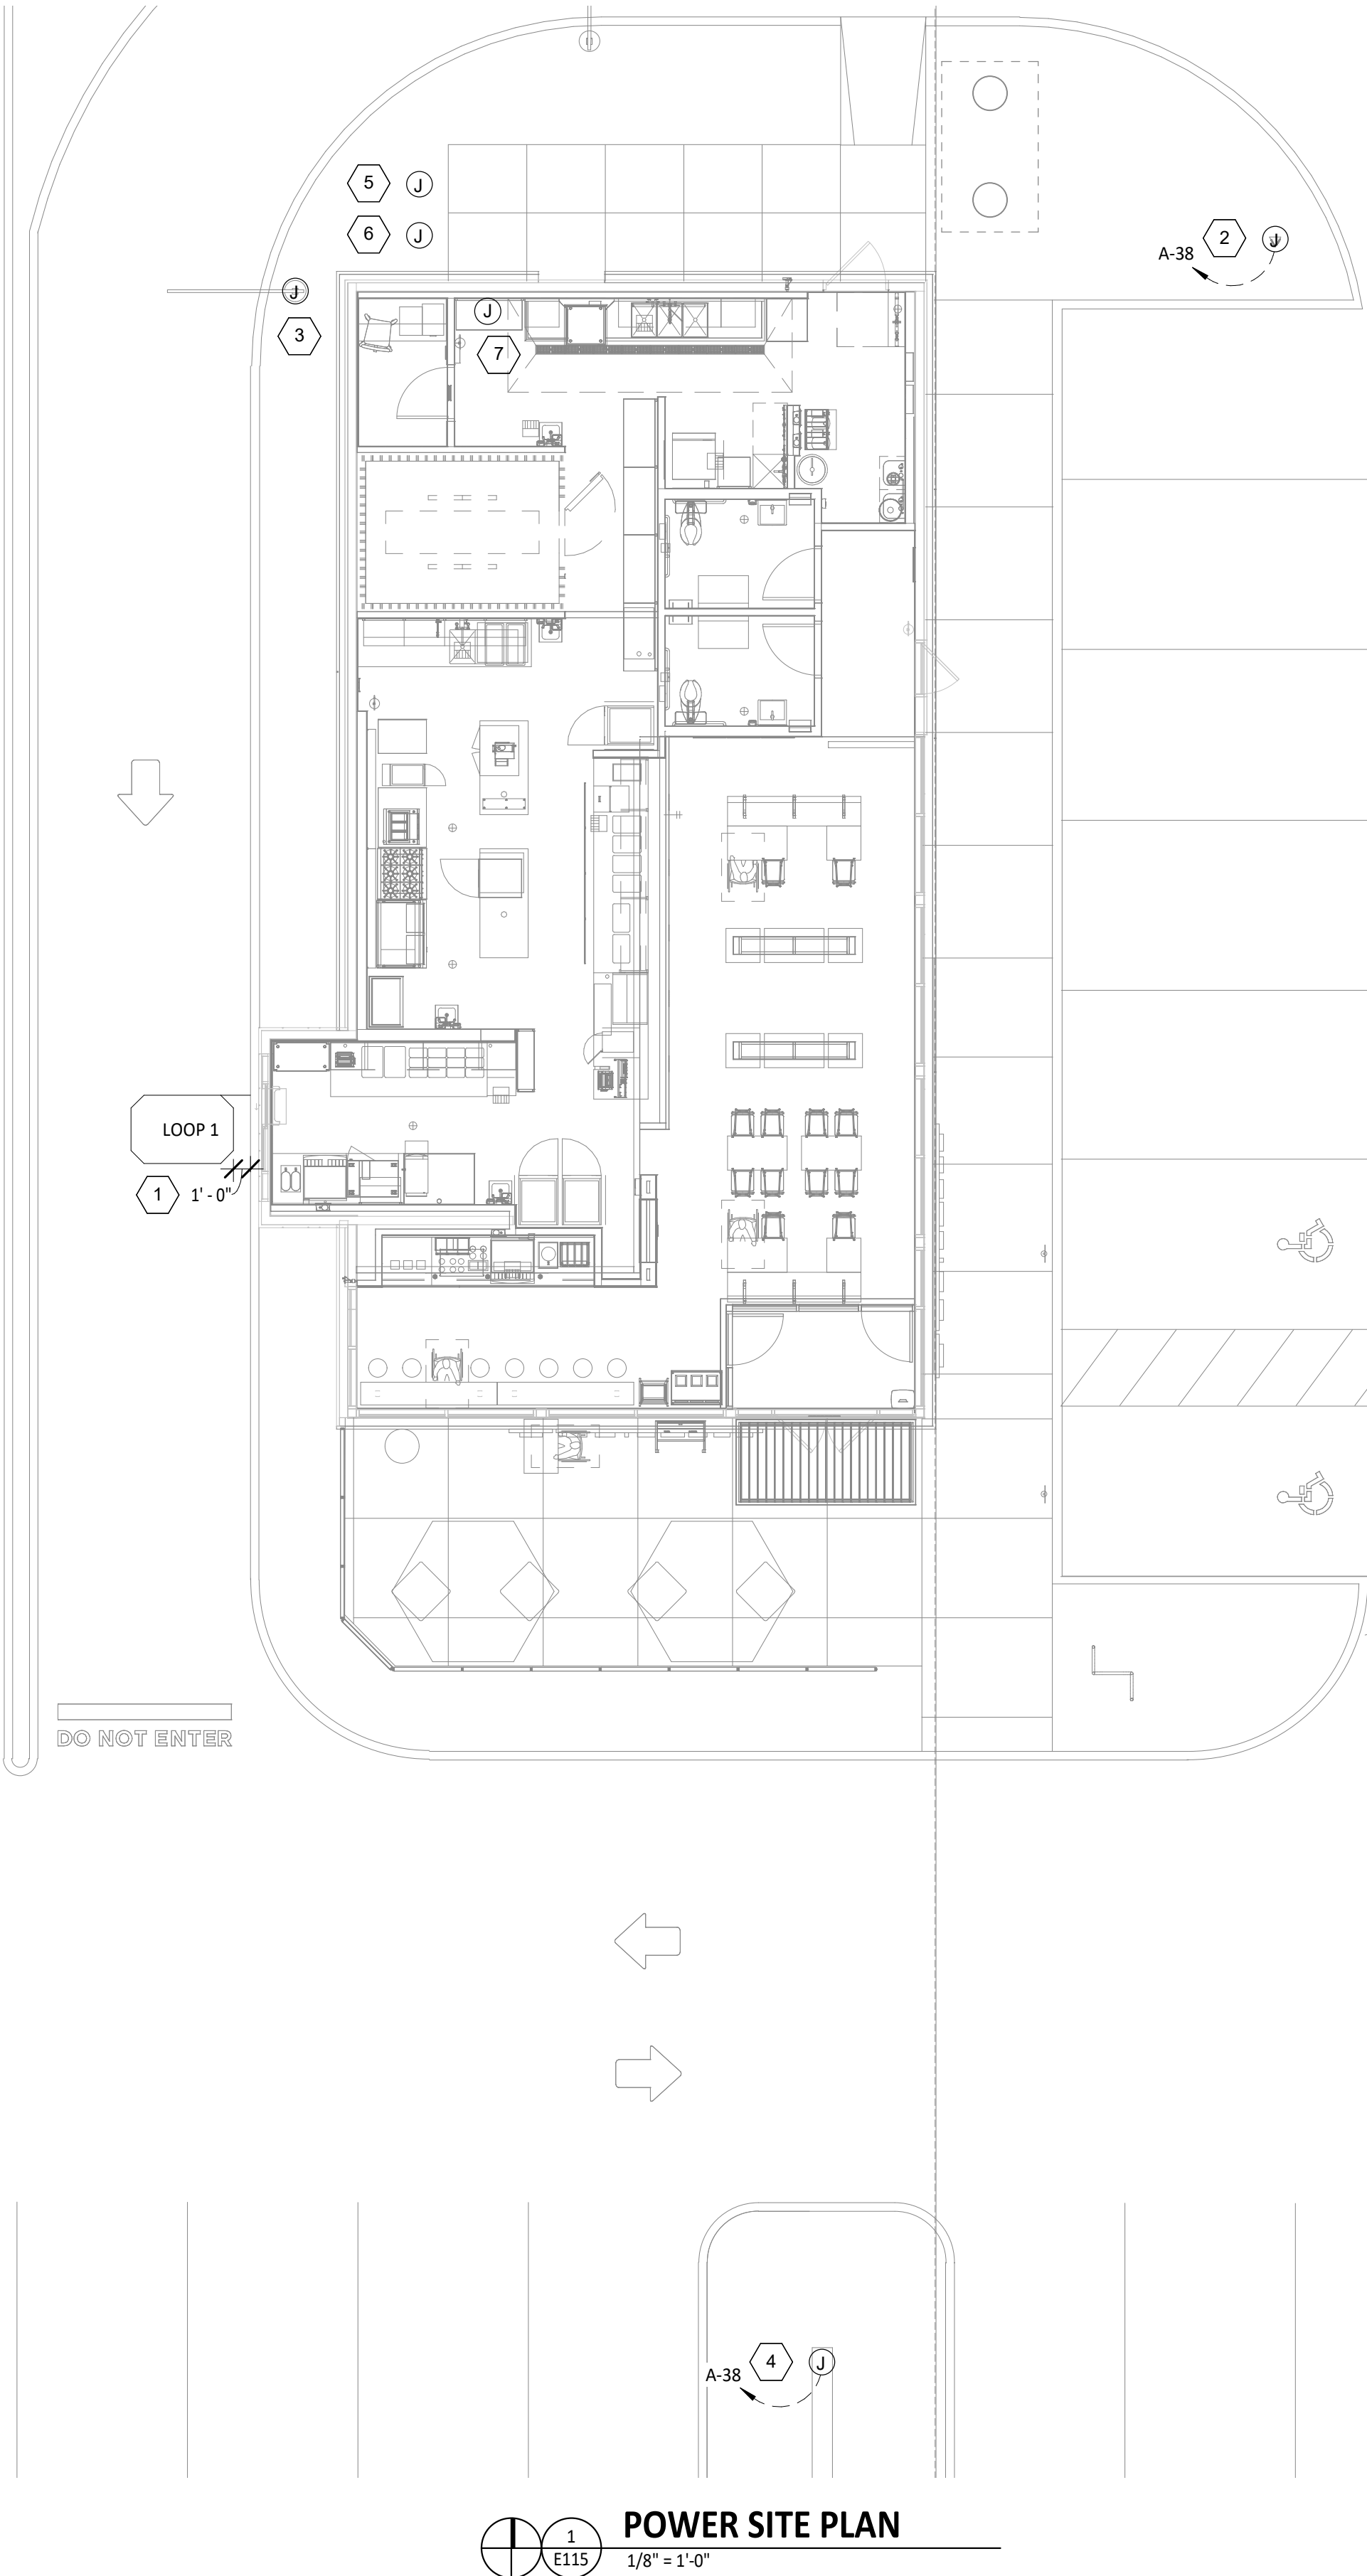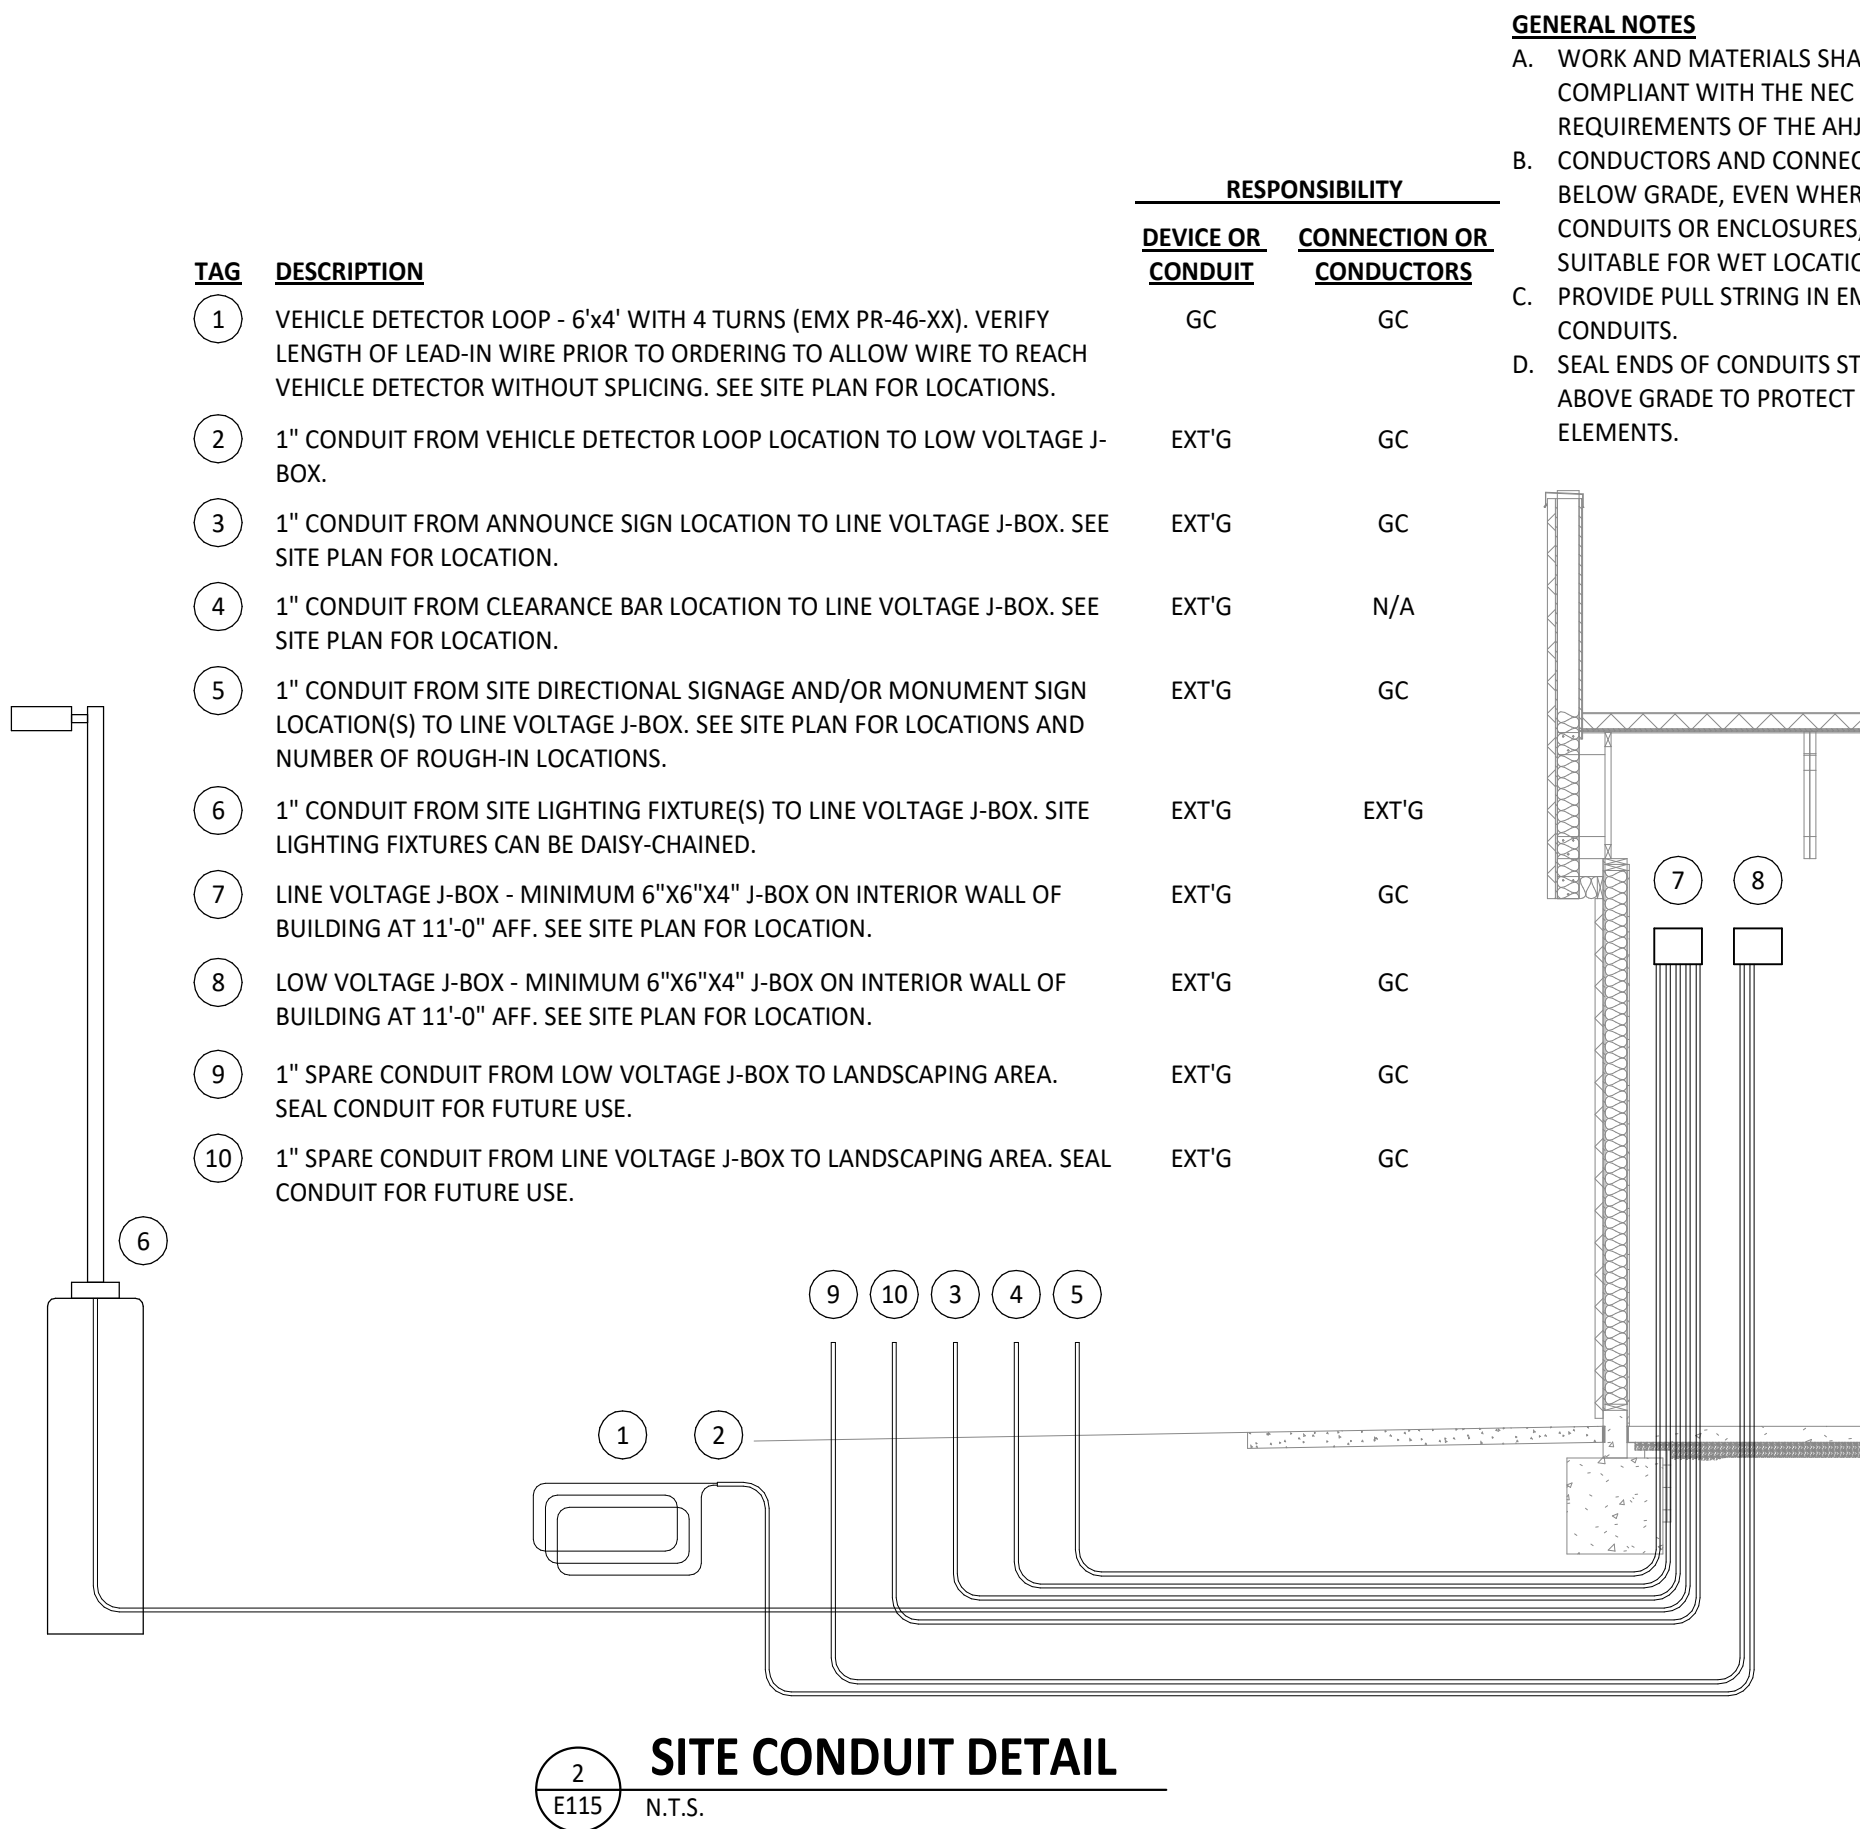

Consultant:

NATIONAL
ENGINEERING

4635 Trueman Blvd, Suite 250
Hilliard, Ohio 43026
Phone: (614) 751-9610
Fax: (614) 552-5240
Contact: Cliff Kigar
(614) 328-2033
ckigar@nationalengineering.com

FOR CONSTRUCTION

COPYRIGHT 2024
THIS DRAWING IS AN INSTRUMENT OF SERVICE
AND AS SUCH REMAINS THE PROPERTY OF
CHIPOTLE MEXICAN GRILL, INC.. PERMISSION FOR
USE OF THIS DOCUMENT IS LIMITED AND CAN BE
EXTENDED ONLY BY WRITTEN AGREEMENT WITH
CHIPOTLE MEXICAN GRILL, INC..



CHIPOTLE MEXICAN GRILL, INC.
PO BOX 182566
COLUMBUS, OH 43218-2566
TELEPHONE: (614) 318-2400
INTERNET: WWW.CHIPOTLE.COM

STORE NO.: 4757
ANDERSON
S SCATTERFIELD RD
ANDERSON, IN 46013

Issue Record:

12/12/2023	PERMIT SET
05/20/2024	BID SET
07/24/2024	CONSTRUCTION SET

Revisions:

Drawn: JEJ
Checked: JEJ/CJK

Project No.
2201198

Contents:

ELECTRICAL SITE
POWER PLAN

E115

Panel Name: BDP		Volts: 120		Mains: LUGS	
Mounting: Recessed		Phases: 1		Amperage: 20 A	
Enclosure: Type 1		Wires: 2			
CKT	Circuit Description		Trip	Poles	Load
	1	POS	15 A	1	0.2 kVA
	2	DML - POS	15 A	1	0.2 kVA
	3	DML - ORDERING SYSTEM	15 A	1	0.7 kVA
	4	OFFICE - SECURITY SYSTEM	15 A	1	0.2 kVA
	5	OFFICE - COMPUTER	15 A	1	0.4 kVA
	6	OFFICE - DVR/ISP	15 A	1	0.5 kVA
				Total Load:	2.2 kVA
				Total Amps:	18 A

VOLTS: 208/120V Wye															PANEL: A		
PHASES: 3															MAINS: MCB		
WIRES: 4															AMPERAGE: 400 A		
MOUNTING: Recessed															ENCLOSURE: Type 1		
ENCLOSURE: Type 1															MCB RATING: 400 A		
CKT #	DESCRIPTION	C/B [A]	# PLS	NOTES	LOAD [A]	LOAD TYPE	LOAD [kVA] A	LOAD [kVA] B	LOAD [kVA] C	LOAD TYPE	LOAD [A]	NOTES	# PLS	C/B [A]	DESCRIPTION	CKT #	
1							6.7	0.0								2	
3	TRANSFORMER T1 (RTU-1) (3-#4, #8 G. IN 1-1/4" C.)	80	3		55.8	C		6.7	0.0		-	0.0	3	60	TVSS (4-#6, #10 G. IN 1" C.)	4	
5									6.7	0.0						6	
7							6.7	0.0								8	
9	TRANSFORMER T2 (RTU-2) (3-#4, #8 G. IN 1-1/4" C.)	80	3		55.8	C		6.7	0.0		-	0.0	3	20	GRIDPOINT 3 PHASE METER (4-#12, #12 G. IN 3/4" C.)	10	
11									6.7	0.0						12	
13	RECEPTACLES - STOREFRONT Receptáculos - Frente del restaurante	20	1		9.0	G	1.1	0.2		G	1.5		1	20	GRIDPOINT TRANSFORMER	14	
15	RECEPTACLES - DINING Receptáculos - Comedor	20	1		1.5	G		0.2	1.2							16	
17	Panel BDP	20	1		18.0	G			2.2	1.2	E	10.4	3	20	HOOD EXHAUST FAN (EF-1) (3-#12, #12 G. IN 3/4" C.)	18	
19	RECEPTACLES - ROOFTOP Receptáculos - Techo	20	1		3.3	G, E	0.4	1.2								20	
21	RECEPTACLES - POS GENERAL Receptáculos - Cajero general	20	1		6.0	G			0.7	0.5						22	
23	SECURITY/AUDIO Seguridad y audio	20	1		3.0	G				0.4	0.5	E	3.9	3	15	HOOD MAKEUP AIR FAN (MAU-1) (3-#12, #12 G. IN 3/4" C.)	24
25	IRRIGATION CONTROLLER	20	1		0.5	F	0.1	0.5								26	
27	RECEPTACLES - OFFICE Receptáculos - Oficina	20	1	GFCI	9.0	G			1.1	0.5	A, E	4.4	1	15	RESTROOM FAN (EF-2)	28	
29	RECEPTACLES - RESTROOMS Receptáculos - Baños	20	1		3.0	G				0.4	1.7	A	13.9	1	20	LIGHTING - KITCHEN Iluminación - Cocina	30
31	RECEPTACLES - DML Receptáculos - Fax	20	1	GFCI	6.9	G	0.8	0.5			A	4.3	1	20	LIGHTING - DINING ROOM Iluminación - Comedor	32	
33	BATHROOM SANITIZER Sanitizante de baño	20	1		0.2	E, -			0.0	0.2	B	1.3	1	20	SIGN LIGHTING Iluminación para letreros	34	
35	HD-1 (CONTROL AND LIGHTS) (control y luces)	15	1		1.5	E				0.2	0.6	Power: A, B	5.2	1	20	LIGHTING - EXTERIOR Iluminación - Exterior	36
37	PICK UP WINDOW NOTIFICATION	20	1		0.3	G	0.0	0.7			B	5.8	1	20	SITE SIGNAGE	38	
39								1.5	0.0		A	0.0	1	20	LIGHTING CONTROL PANEL	40	
41	UNIT HEATER (UH-1)	20	2		14.4	D				1.5	0.2	E	1.5	1	20	PICK-UP WINDOW	42
43	PUW AIR CURTAIN (2-#10, #10 G. IN 3/4" C.)	25	2		20.2	D	2.1	0.0			--	--	1	20	SPARE	44	
45								2.1	0.0			--	--	1	20	SPARE	46
47	SPARE	20	1	--	--					0.0	0.0	--	--	1	20	SPARE	48
49	SPARE	20	1	--	--		0.0	0.0			--	--	1	20	SPARE	50	
51	SPARE	20	1	--	--			0.0	0.0		--	--	1	20	SPARE	52	
53	SPARE	20	1	--	--				0.0	0.0	--	--	1	20	SPARE	54	
							18.5	--			--	--	1	--			
	FEED THRU (PANEL B) (4-500 KCMIL, #1/8 G. IN 4" C.)	0	3	LUGS	156.0	Spare; F			18.7	--	--	--	1	--			
										19.1	--	--	1	--			
PHASE TOTAL [kVA]:							39.5 kVA	40.1 kVA	41.3 kVA								
PHASE TOTAL [AMPS]:							329 A	335 A	345 A								
TYPE	DESCRIPTION	CONNECTED LOAD		DEMAND FACTOR		ESTIMATED DEMAND		PANEL TOTALS									
A	INTERIOR LIGHTING	2 kVA		125.00%		3 kVA		TOTAL CONNECTED kVA: 121 kVA TOTAL CONNECTED AMPS: 335 A TOTAL ESTIMATED kVA: 101.9 kVA TOTAL ESTIMATED AMPS: 283 A									
B	EXTERIOR LIGHTING	1 kVA		125.00%		1 kVA											
C	COMFORT COOLING	40 kVA		100.00%		40 kVA											
D	COMFORT HEATING	7 kVA		100.00%		7 kVA											
E	MISC. MOTOR	6 kVA		100.00%		6 kVA											
F	KITCHEN EQUIPMENT	56 kVA		65.00%		37 kVA											
G	RECEPTACLES	7 kVA		100.00%		7 kVA											



Consultant:

NATIONAL
ENGINEERING
4635 Trueman Blvd, Suite 250
Hilliard, Ohio 43026
Phone: (614) 751-9610
Fax: (614) 552-5240
Contact: Cliff Kigar
(614) 328-2033
ckigar@nationalengineering.com

FOR CONSTRUCTION

COPYRIGHT 2024
THIS DRAWING IS AN INSTRUMENT OF SERVICE
AND AS SUCH REMAINS THE PROPERTY OF
CHIPOTLE MEXICAN GRILL, INC.. PERMISSION FOR
USE OF THIS DOCUMENT IS LIMITED AND CAN BE
EXTENDED ONLY BY WRITTEN AGREEMENT WITH
CHIPOTLE MEXICAN GRILL, INC..



CHIPOTLE MEXICAN GRILL, INC.
PO BOX 182566
COLUMBUS, OH 43218-2566
TELEPHONE: (614) 318-2400
INTERNET: WWW.CHIPOTLE.COM

STORE NO.: 4757
ANDERSON
S SCATTERFIELD RD
ANDERSON, IN 46013

Issue Record:	
12/12/2023	PERMIT SET
05/20/2024	BID SET
07/24/2024	CONSTRUCTION SET

Revisions:	

Drawn:	Checked:
DVB	JEJ


Project No.
2201198

Contents:
ELECTRICAL INTERIOR
ELEVATIONS


E705

ALIGN STOREFRONT RECEPTACLE W/
STOREFRONT MULLION

DINING ROOM ELECTRICAL ELEVATION
3
E705
3/8" = 1'-0"

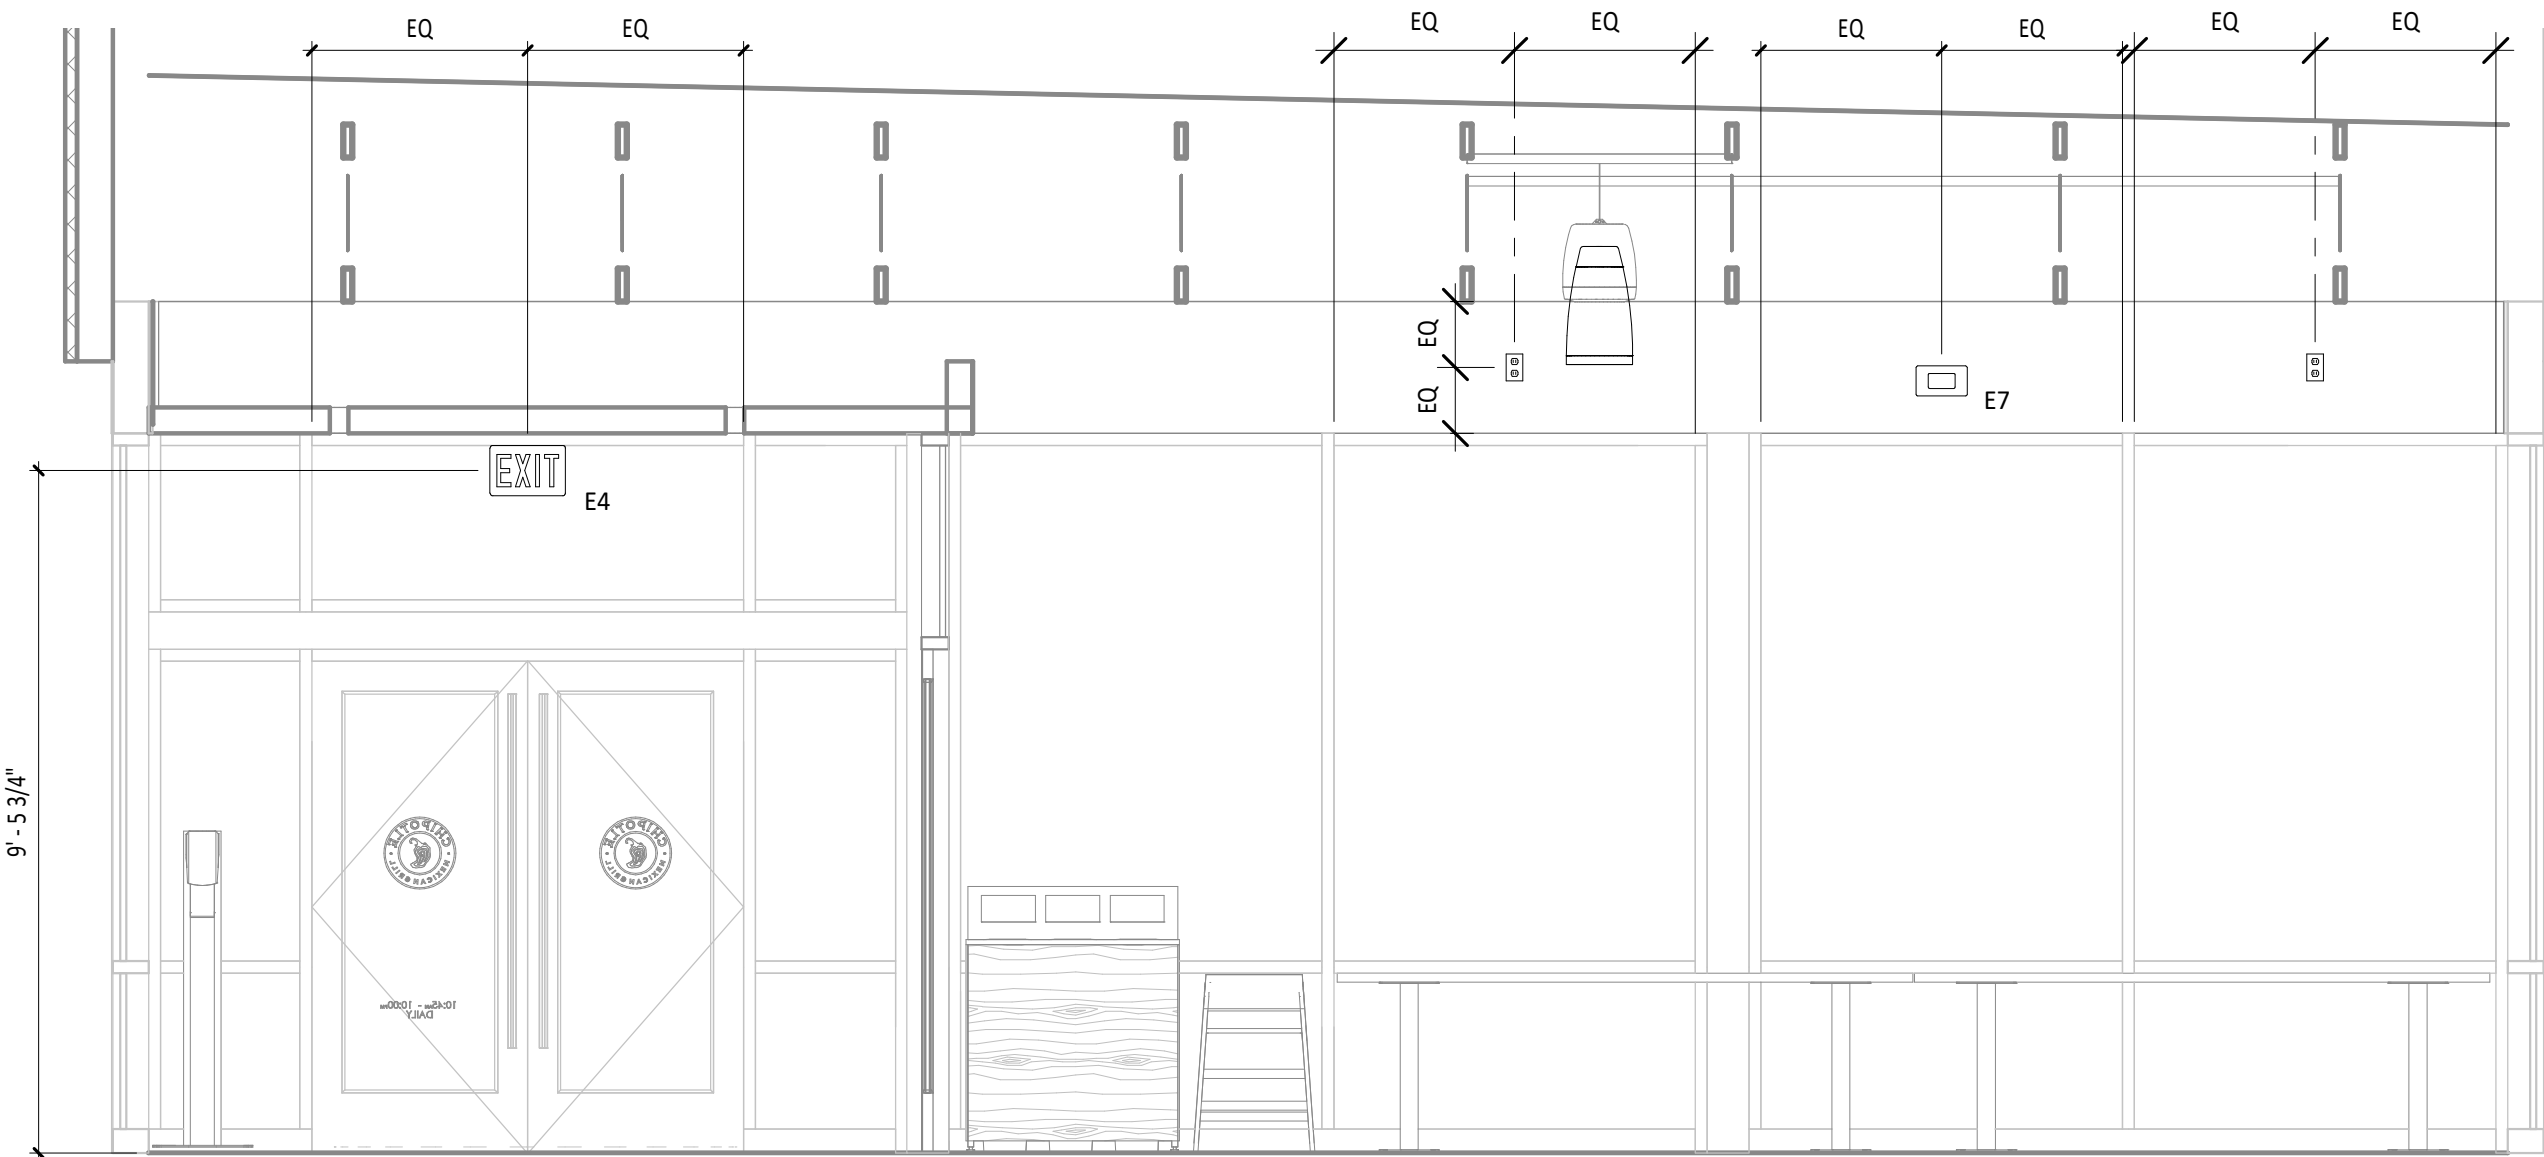

DINING ROOM ELECTRICAL ELEVATION
2
E705
3/8" = 1'-0"

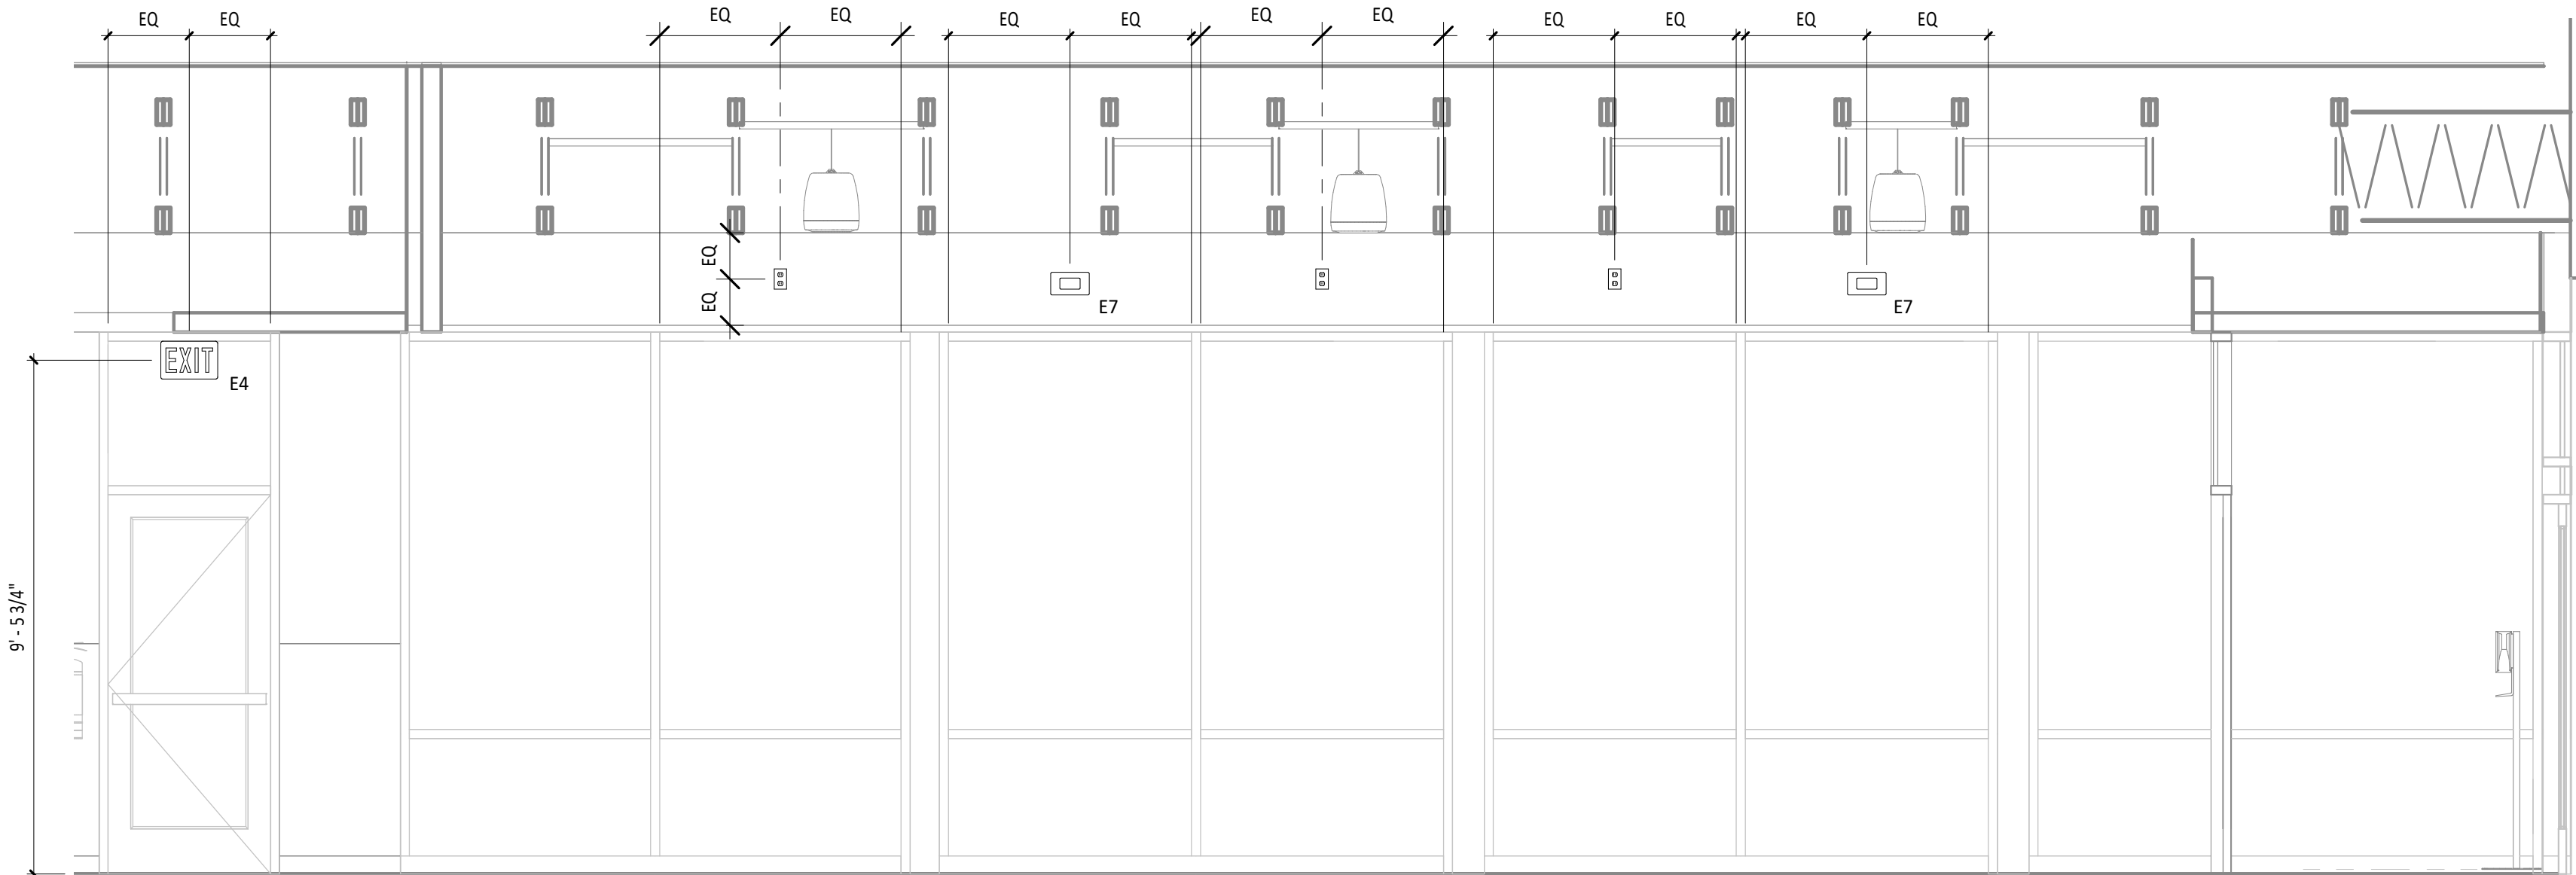


DINING ROOM ELECTRICAL ELEVATION
1
E705
3/8" = 1'-0"

GRIDPOINT DIAGRAM NOTES

1. INSTALL GRIDPOINT THERMOSTATS FURNISHED BY TEMS FOR RTU-1 AND RTU-2. PROVIDE THERMOSTAT WIRING FROM EACH THERMOSTAT TO THE CORRESPONDING ROOFTOP UNIT.
2. PROVIDE CATSE CABLE FROM RTU-1 THERMOSTAT TO J-BOX #2 ABOVE ELECTRICAL PANELS (LEAVE 16" OF CABLE COILED UP INSIDE OF J-BOX #2 AND 16" BEHIND WALL OF THERMOSTAT FOR FINAL CONNECTION TO THE EMS SYSTEM BY THE TEMS) AND LABEL BOTH ENDS OF CABLE "TSTATS".
3. PROVIDE CATSE CABLE(S) BETWEEN THERMOSTATS (LEAVE 16" OF CABLE BEHIND WALL OF EACH THERMOSTAT FOR FINAL CONNECTION BY THE TEMS) AND LABEL BOTH ENDS OF CABLE "TSTAT JUMPER". SEE GRIDPOINT INSTALLATION INSTRUCTIONS FOR TERMINATION INSTRUCTIONS.
4. INSTALL GRIDPOINT ZONE SENSOR MODULES FURNISHED BY TEMS AS SHOWN ON HVAC FLOOR PLAN. PROVIDE 18G-24G SHIELDED TWISTED PAIR FROM ZSM TO CORRESPONDING THERMOSTAT T1 TERMINALS. SEE GRIDPOINT INSTALLATION INSTRUCTIONS FOR TERMINATION INSTRUCTIONS.
5. INSTALL GRIDPOINT SUPPLY PROBE FURNISHED BY TEMS AS SHOWN ON HVAC FLOOR PLAN. PROVIDE 18G-24G SHIELDED TWISTED PAIR FROM SUPPLY PROBE TO CORRESPONDING THERMOSTAT T2 TERMINALS. SEE GRIDPOINT INSTALLATION INSTRUCTIONS FOR TERMINATION INSTRUCTIONS.
6. PROVIDE 3/4" LIQUIDTIGHT CONDUIT FROM DISH SANITIZING MACHINE TO LOW-VOLTAGE JUNCTION BOX OR TRIM RING FLUSH MOUNTED TO WALL. PROVIDE CONTINUOUS (NOT SPLICED) CATSE CABLE FROM DISH SANITIZING MACHINE TO OFFICE (ABOVE LAY-IN CEILING) WITH 54" SLACK WITHIN THE DISH MACHINE AND 10" SLACK ABOVE THE LAY-IN CEILING. PROVIDE RJ-12 PLUG ON CABLE AT DISH MACHINE END WITH BLUE WIRE CONNECTED TO PIN 3 AND BLUE/WHITE WIRE CONNECTED TO PIN 4. LABEL CABLE ON BOTH ENDS WITH "DISHWASHER".
7. PROVIDE CATS CABLE FROM J-BOX #2 TO OFFICE ABOVE LAY-IN CEILING AND LABEL "RS-485 COMMS" ON BOTH ENDS OF THE CABLE. LEAVE 10" OF SLACK CABLE ABOVE OFFICE CEILING AND 16" OF SLACK CABLE INSIDE OF J-BOX #2.
8. PROVIDE CABLE (18-24AWG SHIELDED TWISTED PAIR) FROM J-BOX #2 TO OFFICE ABOVE LAY-IN CEILING AND LABEL "EMS POWER" ON BOTH ENDS OF THE CABLE. LEAVE 10" OF SLACK CABLE ABOVE OFFICE CEILING AND 16" OF SLACK CABLE INSIDE OF J-BOX #2.
9. PROVIDE SURFACE MOUNT 10" X 10" X 4" NEMA 1 ENCLOSURES ABOVE PANELBOARDS AND 6" BELOW CEILING.
10. PROVIDE 3/4" CONDUIT WITH INSULATING BUSHING ON END CONCEALED IN WALL FROM J-BOX #2 TO 6" ABOVE LAY-IN CEILING.
11. PROVIDE 3/4" CONDUIT(S) FROM J-BOX #1 TO J-BOX #2.
12. PROVIDE EMPTY 1" CONDUIT(S) FROM PANELBOARD(S) TO J-BOX #1 FOR FUTURE CT WIRING BY TEMS.
13. FIRST PANELBOARD FED FROM ELECTRICAL SERVICE. PROVIDE WITH (1) 20A/3-POLE CIRCUIT BREAKER (FOR GRIDPOINT 3 PHASE METER), IF PANELBOARD HAS 120V CIRCUITS AVAILABLE THEN ALSO PROVIDE (1) 20/1-POLE CIRCUIT BREAKER (FOR GRIDPOINT TRANSFORMER).
14. IF SPACE HAS MULTIPLE ELECTRICAL SERVICES THEN PROVIDE A "J-BOX #1" AND ASSOCIATED BREAKERS, CONDUITS, AND CONDUCTORS ON THE FIRST PANELBOARD FED FROM EACH ELECTRICAL SERVICE.
15. FOR EACH ELECTRICAL SERVICE PROVIDE (1) SET OF [(4) #12, #12 G.] FROM 3-POLE GRIDPOINT CIRCUIT BREAKER AND, IF THE PANELBOARD HAS 120V CIRCUITS AVAILABLE, (1) SET OF [(2) #12, #12 G.] FROM 1-POLE GRIDPOINT CIRCUIT BREAKER IN 3/4" CONDUIT CONCEALED IN WALL TO J-BOX #1. TERMINATE IN J-BOX #1 WITH 16" SLACK FOR FINAL CONNECTION BY TEMS.
16. IF THE PANELBOARD DOES NOT HAVE 120V CIRCUITS AVAILABLE PROVIDE A 1-POLE 120V 20A CIRCUIT BREAKER IN A PANEL WITH A 120V CIRCUIT AVAILABLE. PROVIDE (1) SET OF [(2) #12, #12 G.] FROM THE GRIDPOINT CIRCUIT BREAKER IN 3/4" CONDUIT CONCEALED IN WALL TO J-BOX #1. TERMINATE IN J-BOX #1 WITH 16" SLACK FOR FINAL CONNECTION BY TEMS.
17. GRIDPOINT CONTROLLER PROVIDED BY TEMS
18. PROVIDE HORIZONTAL SINGLE-GANG J-BOX BELOW FUTURE GRIDPOINT CONTROLLER LOCATION AS SHOWN. PROVIDE 3/4" CONDUIT WITH PULL STRING AND INSULATING BUSHING FROM J-BOX TO 6" ABOVE OFFICE LAY-IN CEILING.

NOTE:
ARRANGEMENT SHOWN IS
DIAGRAMMATIC - SEE PLANS FOR ACTUAL
DEVICE LOCATIONS.

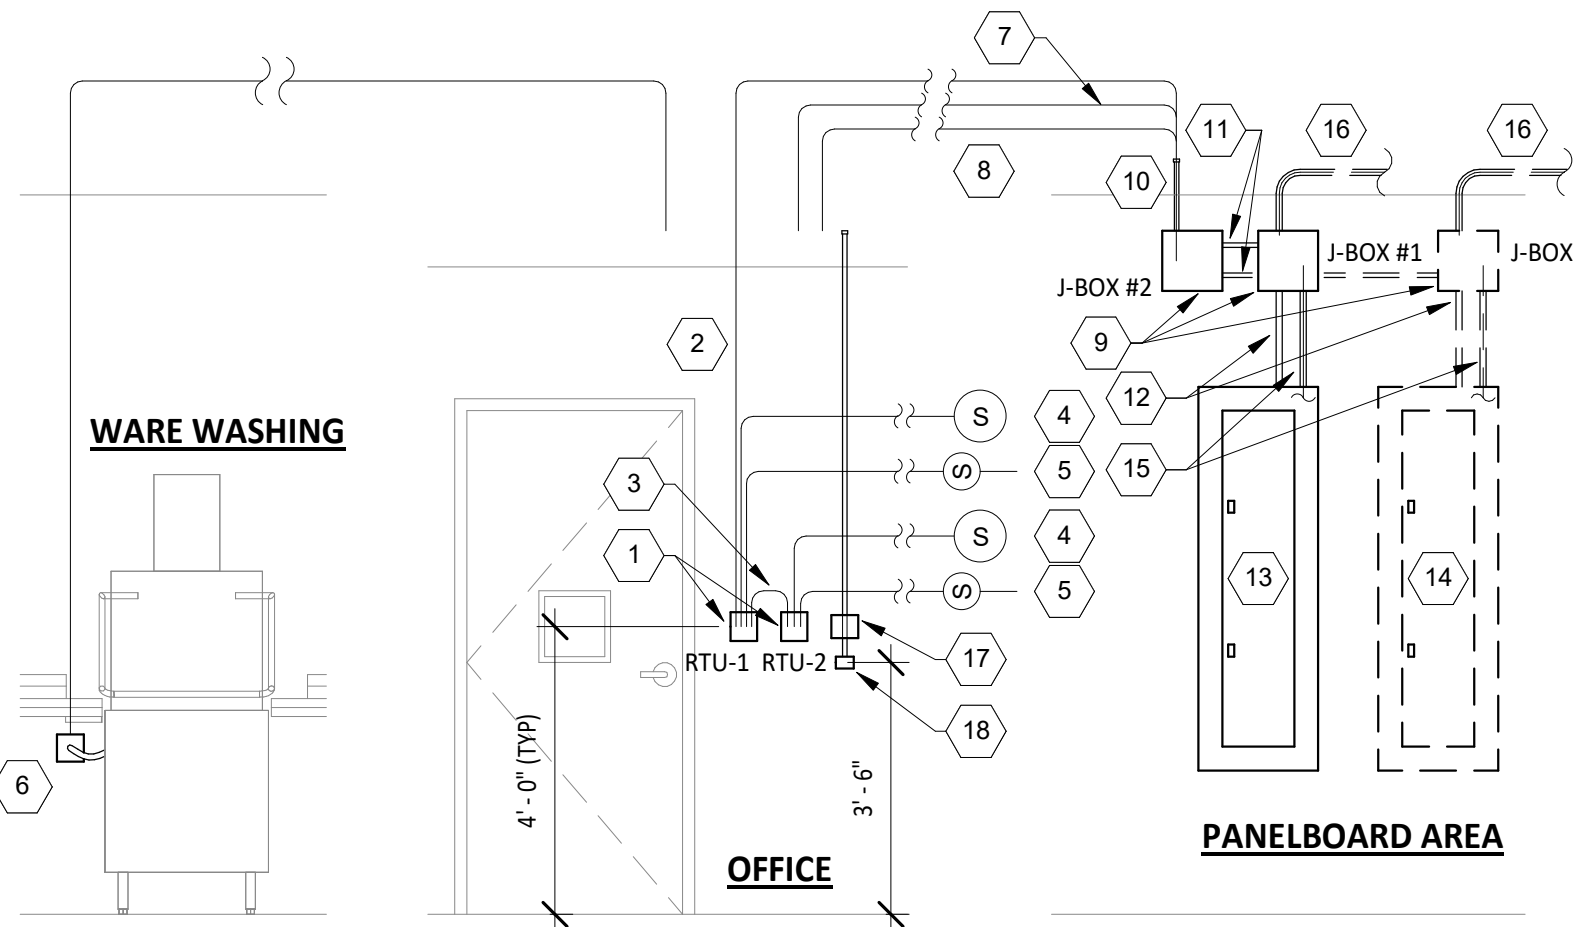

GRIDPOINT WIRING DIAGRAM

SEQUENCE OF OPERATIONS

- A. EMERGENCY LIGHT FIXTURES, EXIT SIGNS, LOCALLY-SWITCHED FIXTURES, AND FIXTURES DESIGNATED AS NIGHT LIGHTS ARE NOT CONTROLLED THROUGH THE RELAY PANEL.
- B. ALL TIMES NOTED SHALL BE LOCAL TIME AND SHALL AUTOMATICALLY ADJUST FOR DAYLIGHT SAVINGS TIME, IF APPLICABLE.
- C. ALL KITCHEN LIGHTING CIRCUITS AND RESTROOM EXHAUST FAN CIRCUIT (R1, R2, R7) SHALL BE ENERGIZED AT FULL POWER FROM 7:00AM UNTIL MIDNIGHT AND SHALL BE DE-ENERGIZED AT OTHER TIMES.
- D. ALL DINING ROOM LIGHTING CIRCUITS (R4, R5, R6) SHALL BE ENERGIZED FROM 10:00AM UNTIL MIDNIGHT AND SHALL BE DE-ENERGIZED AT OTHER TIMES.
- E. EXTERIOR LIGHTING/SIGNAGE RELAY (R8) SHALL BE ENERGIZED FROM ONE HOUR BEFORE SUNSET UNTIL ONE HOUR AFTER CLOSING AND SHALL BE DE-ENERGIZED AT OTHER TIMES.
- F. OVERRIDES: WHEN ONE OF THE OVERRIDE BUTTONS IS PRESSED THE SYSTEM WILL GO INTO OVERRIDE MODE FOR THE DURATION NOTED BELOW OR UNTIL THE NEXT SCHEDULED EVENT. FOLLOWING THIS PERIOD THE RELAYS WILL RETURN TO THE CURRENT SCHEDULED CONDITION. DURING THIS OVERRIDE TIME THE CORRESPONDING LAMP WILL ILLUMINATE ON THE OVERRIDE BUTTON.
- G. INTERIOR (CHANNEL 1): WHEN THE INTERIOR OVERRIDE ON OR OFF BUTTON IS PRESSED (CHANNEL 1) RELAYS R1, R2, R4, R5, R6, AND R7 WILL BE ENERGIZED OR DE-ENERGIZED FOR A DURATION OF ONE (1) HOUR.
- H. KITCHEN DIMMING (CHANNEL 2): WHEN THE KITCHEN NORMAL/DIM OVERRIDE ON OR OFF BUTTON IS PRESSED (CHANNEL 2) RELAY R2 WILL BE ENERGIZED OR DE-ENERGIZED FOR A DURATION OF ONE (1) HOUR.
- I. DINING DIMMING (CHANNEL 3): WHEN THE DINING NORMAL/DIM OVERRIDE ON OR OFF BUTTON IS PRESSED (CHANNEL 3) RELAYS R5 AND R6 WILL BE ENERGIZED OR DE-ENERGIZED FOR A DURATION OF ONE (1) HOUR.
- J. EXTERIOR (CHANNEL 4): WHEN THE EXTERIOR OVERRIDE ON OR OFF BUTTON IS PRESSED (CHANNEL 4) RELAY R8 WILL BE ENERGIZED OR DE-ENERGIZED FOR A DURATION OF ONE (1) HOUR.
- K. VERIFY THAT TIME, TIME ZONE, AND LONGITUDE/LATITUDE ARE SET CORRECTLY ON LCP. VERIFY WITH STORE OPERATIONS THAT THE ON/OFF TIMES ARE COMPATIBLE WITH THE STORE OPERATING HOURS PRIOR TO TURNOVER.

CO2 ALARM OPTIONS	
CO2 DETECTOR	X
CO2 REMOTE DISPLAY UNIT	X
REMOTE STROBE	
RELAY	

INSTALL STROBE WITH WIRING TO CO2 DETECTOR SEU OR RDU (FURNISHED BY CO2AS) (IF REQUIRED). PROVIDE 3/4" CONDUIT IN WALL FROM STROBE LOCATION TO ABOVE CEILING TO CONCEAL WIRING.

CO2 TANK (BULK TANK OR CANISTERS) PROVIDE GFCI RECEPTACLE J-BOX ADJACENT TO THE CO2 TANK/BAG-IN-BOX AS SHOWN ON THE ELECTRICAL POWER PLAN.

INSTALL CO2METER RAD-0102-06 CARBON DIOXIDE STORAGE SAFETY ALARM SEU (FURNISHED BY CO2AS) ADJACENT TO THE CO2 TANK/BAG-IN-BOX AS SHOWN.

CONNECT THE SYSTEM POWER TO THE RECEPTACLE AS SHOWN. INSTALL CABLE TO MINIMIZE SLACK AT CO2 DETECTOR. SECURE CABLE TO WALL.

AT SEU J-BOX, INSTALL MOUNTING PLATE TO TOP SCREW HOLE OF J-BOX WITH THE MOUNTING PLATE EXTENDING ABOVE THE TOP OF THE J-BOX IN THE ORIENTATION SHOWN.

CO2 ALARM DETAIL

N.T.S.

ELECTRICAL CONNECTIONS SHALL BE ON THE OPPOSITE SIDE OF THE DISH MACHINE FROM THE 3-COMP SINK. IF THIS IS ON THE LEFT SIDE OF THE DISH MACHINE THEN LIQUID TIGHT CONDUIT SHALL BE ROUTED BEHIND THE DISH MACHINE TO THE ELECTRICAL CONNECTIONS ON THE RIGHT SIDE OF THE DISH MACHINE..

POWER FOR DISH SANITIZING MACHINE SHALL BE FED FROM A DEDICATED 2-POLE LOCKABLE CIRCUIT BREAKER. PROVIDE FINAL CONNECTION FROM J-BOX IN WALL TO DISH SANITIZING MACHINE USING LIQUIDTIGHT FLEXIBLE METAL CONDUIT.

PROVIDE CONDUITS AND WIRING FOR GRIDPOINT CONNECTION TO DSM AS SHOWN IN DETAIL 8/E710.

DISH SANITIZING MACHINE ELECTRICAL DETAIL

N.T.S.

TERMINATE CONDUITS ABOVE CEILING WITH CONDUIT BUSHINGS. TYPICAL.

PROVIDE CONTINUOUS CATS CABLE WITH RJ45 CONNECTOR ON EACH END FROM THE SEU TO THE RDU AND FROM EACH STROBE TO A SEU/RDU (IF REQUIRED). CATS CABLES SHALL NOT BE SPLICED.

PROVIDE 1" CONDUITS CONCEALED IN WALL FROM SEU AND RDU J-BOX TO ABOVE THE LAY-IN CEILING. ALL CO2 MONITOR CABLING (OTHER THAN THE SEU POWER CABLE) SHALL BE CONCEALED WITHIN CONDUITS.

INSTALL CO2 ALARM RDU (FURNISHED BY CO2AS) AT ENTRANCE TO THE CO2 STORAGE AREA AS SHOWN.

CO2 REMOTE DISPLAY UNIT/J-BOX 48" AFF

PROVIDE JUNCTION BOX AT ENTRANCE TO THE CO2 STORAGE AREA AS SHOWN ON THE ELECTRICAL POWER PLAN.

AT RDU J-BOX, INSTALL MOUNTING PLATE TO TOP SCREW HOLE OF J-BOX WITH THE MOUNTING PLATE EXTENDING DOWN BELOW THE TOP OF THE J-BOX IN THE ORIENTATION SHOWN.

RDU J-BOX

INSTALL 2000 VA WALL-MOUNTED UPS FURNISHED BY CMG.

PROVIDE CONNECTION FROM TERMINAL STRIP IN BDP TO THE INPUT AND THE OUTPUT OF THE UPS IN OFFICE PER THE MANUFACTURER'S INSTALLATION INSTRUCTIONS. FINAL CONNECTION TO UPS SHALL BE THROUGH A SINGLE 5-20R RECEPTACLE AND A 5-20P FLANGED INLET.

LEGEND

PREWIRED CONDUCTOR
FIELD-WIRED CONDUCTOR

NOTE
REVIEW BDP PANEL INSTALLATION INSTRUCTIONS PRIOR TO INSTALLATION.

BYPASS DISTRIBUTION PANEL WIRING DIAGRAM

N.T.S.

INSTALL SURFACE MOUNTED TVSS UNIT (CURRENT TECHNOLOGY MODEL CG60-120/208-3GV) FURNISHED BY CMG. FEED THROUGH 60A 3PH CIRCUIT BREAKER. LOCATE AS CLOSE AS POSSIBLE TO TOP OF PANELBOARD NEAR CEILING. CONDUCTORS SHALL NOT HAVE SHARP BENDS. INSTALL TVSS UNIT PER MANUFACTURER'S INSTALLATION INSTRUCTIONS.

KEEP CONDUCTOR LENGTH AS SHORT AS POSSIBLE.

INSTALL PANELS A AND B PROVIDED BY TPS AND INSTALL PANEL BDP AS SHOWN. CIRCUIT BREAKERS IN PANELS A AND B SHALL HAVE A SERIES COMBINATION RATING OF AT LEAST 65,000 AIC WHEN USED IN SERIES WITH THE 400A MCB IN PANEL A. PROVIDE THE FOLLOWING MARKING ON THE PANELBOARDS:

" CAUTION - SERIES COMBINATION SYSTEM RATED 65,000 AMPERES. IDENTIFIED REPLACEMENT COMPONENTS REQUIRED."

PROVIDE (3) #10, #10 G. IN 3/4" C.


PROVIDE (2) 30 KVA TRANSFORMERS WITH 208V DELTA PRIMARY AND 460V WYE SECONDARY ON ROOF AS SHOWN ON SHEET E110.

PROVIDE (3) #10, #10 G. IN 3/4" C.

PROVIDE GROUNDING AND BONDING AT EACH TRANSFORMER AS SHOWN IN DETAIL 5/E710.


MAIN DISTRIBUTION DIAGRAM

N.T.S.

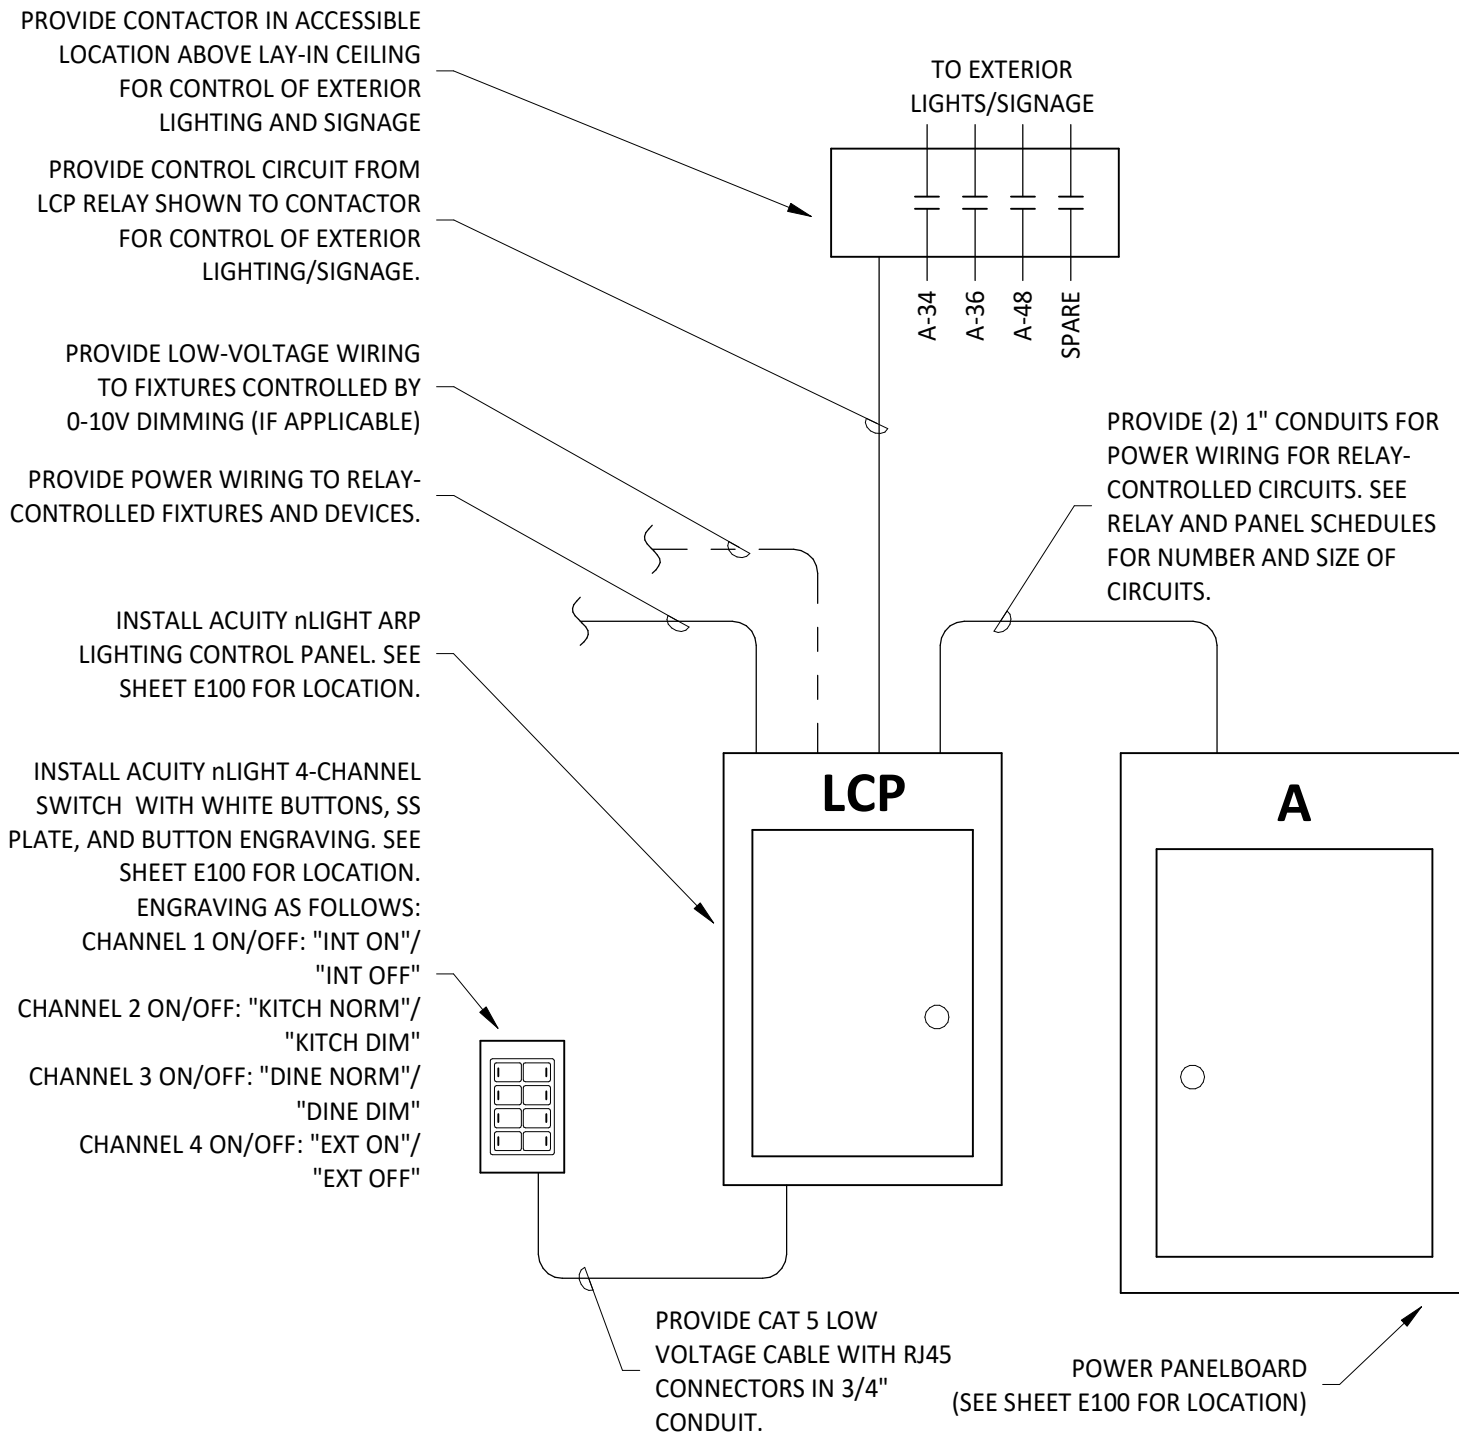


INTERIOR LIGHTING CONTROL DIAGRAM

N.T.S.

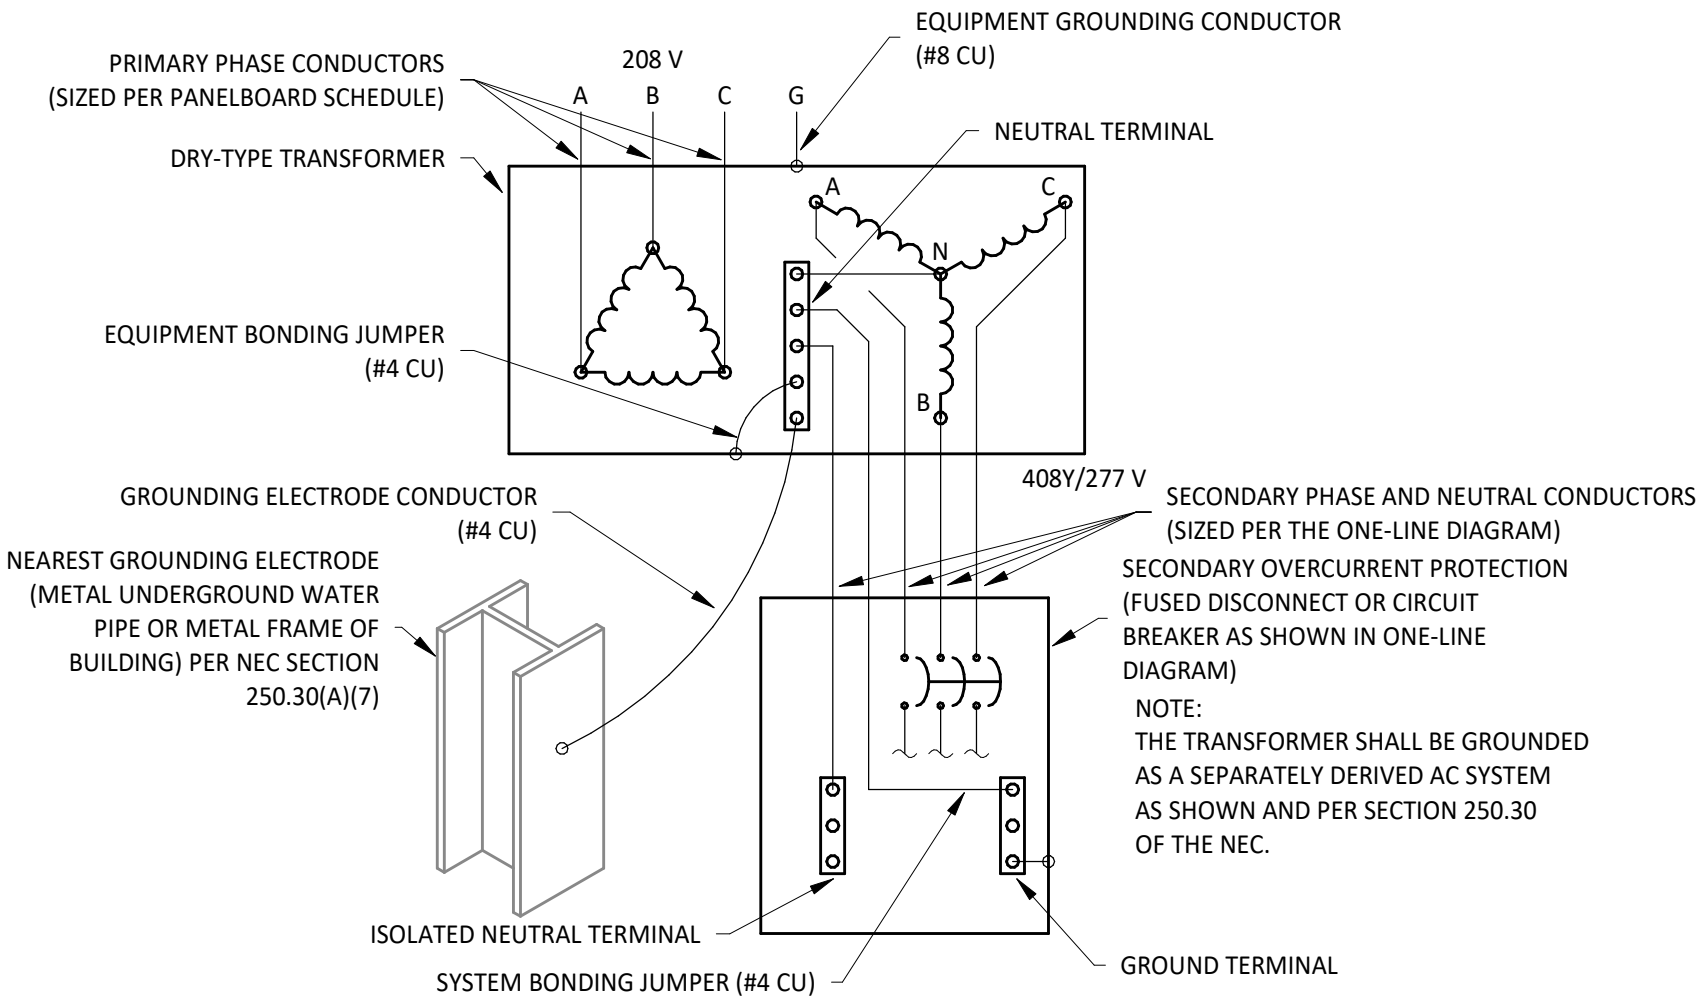

TRANSFORMER GROUNDING AND BONDING DETAIL

N.T.S.

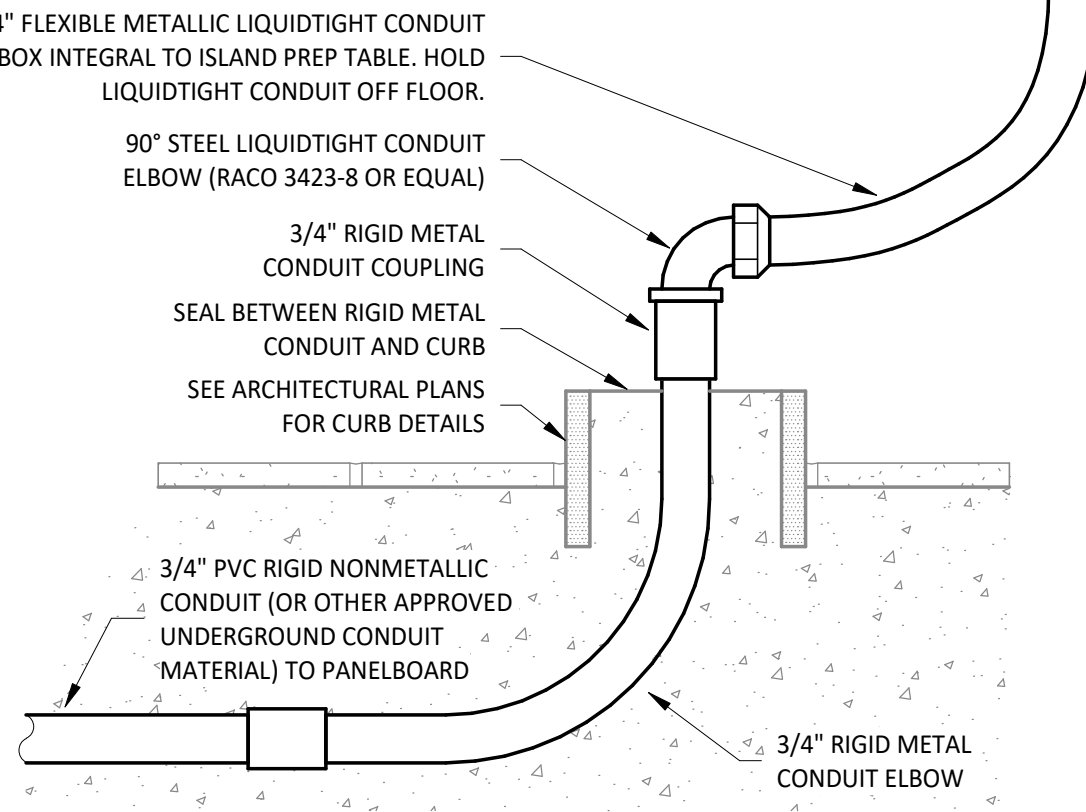

PEDESTAL OUTLET DETAIL

N.T.S.

Consultant:



4635 Trueman Blvd, Suite 250
Hilliard, Ohio 43026
Phone: (614) 751-9610
Fax: (614) 552-5240
Contact: Cliff Kigar
(614) 328-2033
ckigar@nationalengineering.com

FOR CONSTRUCTION

COPYRIGHT 2024
THIS DRAWING IS AN INSTRUMENT OF SERVICE
AND AS SUCH REMAINS THE PROPERTY OF
CHIPOTLE MEXICAN GRILL, INC.. PERMISSION FOR
USE OF THIS DOCUMENT IS LIMITED AND CAN BE
EXTENDED ONLY BY WRITTEN AGREEMENT WITH
CHIPOTLE MEXICAN GRILL, INC..



CHIPOTLE MEXICAN GRILL, INC.
PO BOX 182566
COLUMBUS, OH 43218-2566
TELEPHONE: (614) 318-2000
INTERNET: WWW.CHIPOTLE.COM

STORE NO.: 4757

ANDERSON
S SCATTERFIELD RD
ANDERSON, IN 46013

Issue Record:

12/12/2023	PERMIT SET
05/20/2024	BID SET
07/24/2024	CONSTRUCTION SET

Revisions:

1	05-20-2024	RTU REVISION
---	------------	--------------

Drawn:

Checked:

JEI/CLK

Project No.

2201198

Contents:

ELECTRICAL DETAILS

E710