

CONSTRUCTION BULLETIN



C.B. #

01

Issued By: Julia Hoban, Red Architecture

Project: Walnut Hills – Store 4870 – CMG1144

Issued on: 05/09/2024 Regarding Construction Documents dated: 05/08/2024

Issued to:

DM: John Myers – Chipotle Mexican Grill

CM: Jay Mauger – Chipotle Mexican Grill

DC: Heather Conley – Chipotle Mexican Grill

GC: Nicole Sherry – Derek Inc.

NOTICE

The following list of items represent revisions and/or corrections to the Construction Documents bearing the date listed above. If the Contractor feels that any item causes a change to the requirements of the Contract Documents, the Contractor shall immediately give written notice to the Owner and Architect.

#1	Revision	X	Per Direction of: <i>permitting jurisdiction</i>
	Correction		
<i>The hand sink located in the prep area shifted to the other side of the prep sink per comments from the health department. The prep sink and associated floor sink below shifted slightly also to accommodate.</i>			
<i>The following sheets were revised and clouded as Revision 1: G000, G001, A101a, A130, A702, P100, P110, E110</i>			

#2	Revision	X	Per Direction of: <i>permitting jurisdiction, owner</i>
	Correction		
<i>NL was redefined to mean Normal Power Egress Lighting. Light fixture P6 was added to the NL circuit.</i>			
<i>Conductor and conduit sizes were added to the main distribution diagram.</i>			
<i>RTUs were swapped from York units to Carrier, rooftop plan was adjusted.</i>			
<i>The following sheets were revised and clouded as Revision 2: G000, A140, M100, M600, P100, E010, E100, E110, E600, E710</i>			

<u>ZONING</u>	CITY OF CINCINNATI	<u>BUILDING</u>	CITY OF CINCINNATI	<u>HEALTH</u>	CITY OF CINCINNATI
<u>DEPARTMENT:</u>	BUILDINGS AND INSPECTIONS	<u>DEPARTMENT:</u>	BUILDINGS AND INSPECTIONS	<u>DEPARTMENT:</u>	HEALTH DEPARTMENT
	805 CENTRAL AVE, SUITE 500		805 CENTRAL AVE, SUITE 500		3101 BURNET AVENUE
	CINCINNATI, OH 45202		CINCINNATI, OH 45202		CINCINNATI, OH 45229
	CONTACT: WES MUNZEL		CONTACT: MARK ABBOT		T: (513) 357-7200
	E: weston.munzel@cincinnati-oh.gov		E: mark.abbot@cincinnati-oh.gov		
	T: (513) 352-3271		T: (513) 352-3271		
	F: (513) 352-2579		F: (513) 352-2579		
<u>FIRE</u>	CINCINNATI FIRE DEPARTMENT	<u>WATER</u>	GREATER CINCINNATI WATER WORKS	<u>SEWER</u>	METROPOLITAN SEWER DISTRICT
<u>DEPARTMENT:</u>	430 CENTRAL AVE	<u>UTILITY:</u>	4747 SPRING GROVE AVENUE	<u>UTILITY:</u>	1600 GEST STREET
	CINCINNATI, OH 45202		CINCINNATI, OH 45232		CINCINNATI, OH 45204
	T: (513) 352-6242		T: (513) 591-7700		CONTACT: ROB KERN
					T: (513) 244-5588
<u>NATURAL</u>	DUKE ENERGY OHIO	<u>ELECTRICAL</u>	DUKE ENERGY OHIO	<u>TELEPHONE</u>	TBD
<u>GAS UTILITY:</u>	424 GEST STREET	<u>UTILITY:</u>	424 GEST STREET	<u>UTILITY:</u>	
	CINCINNATI, OH 45203		CINCINNATI, OH 45203		
	T: (877) 700-3853		T: (877) 700-3853		

<u>LANDLORD:</u>	SKYLINE CHILI FRANCHISE 2951 MADISON RD CINCINNATI, OH 45209 CONTACT: MICHAEL MISLEH E: mmisleh@mislehfamily.com T: (513) 841-9285	<u>TENANT:</u>	CHIPOTLE MEXICAN GRILL PO BOX 182566 COLUMBUS, OH 43218-2566 CONTACT: HEATHER CONLEY E: heather.koch@chipotle.com T: (380) 222-7248	<u>ARCHITECT:</u>	RED ARCHITECTURE & PLANNING 589 W NATIONWIDE BLVD, SUITE B COLUMBUS, OH 43215 CONTACT: JULIA HOBAN E: jhoban@redarchitects.com T: (614) 487-8770 F: (614) 487-8777
<u>MECHANICAL</u> <u>ELECTRICAL</u> <u>PLUMBING</u> <u>ENGINEER:</u>	NATIONAL ENGINEERING 4635 TRUENAM BLVD, SUITE 250 HILLIARD, OH 43026 CONTACT: CLIFF KIGAR E: ckigar@nationalengineering.com T: (614) 328-2035	<u>STRUCTURAL</u> <u>ENGINEER:</u>	JEZERINAC GEERS & ASSOCIATES 5640 FRANZT ROAD DUBLIN, OH 43017 CONTACT: ANDY HEIGLEY E: aheigley@jgaeng.com T: (614) 766-0066 F: (614) 481-1223		


NOTE to GC:
**FOR ALL WATER, SEWER,
 NATURAL GAS, & ELECTRICITY
 UTILITIES CONTACT:**

EBI CONSULTING
 21 B ST.
 BURLINGTON, MA 01803
 CONTACT: JULIO VERA
 E: JVERA@EBICONSULTING.COM
 T: (787) 344-1439

BROADWAY NATIONAL
 100 DAVIDS DR.
 HAUPPAUGE, NY 11788
 CONTACT: LANETTE LUCKSAVAGE
 E: llucksavage@broadwaynational.com
 T: (631) 737-3140 x3008

	EXTERIOR ELEVATION MARKER		COLUMN GRID LABEL		KITCHEN EQUIPMENT NUMBER
	INTERIOR ELEVATION MARKER	Room name 	ROOM NAME & NUMBER		WASHROOM ACCESSORIES NUMBER
	SECTION MARKER		REVISION NUMBER		WALL TAG
	SECTION / DETAIL		DOOR NUMBER		LEVEL TARGET
	View Name View Scale		MISCELLANEOUS EQUIPMENT NUMBER		NORTH ARROW
	VIEW SCALE		FURNITURE NUMBER		FINISH TAG

Q.	CENTER LINE	FC	FOR CONSTRUCTION FIBERGLASS REINFORCED PANEL	NO	NUMBER	TLS	TENANT'S LIGHT/LAMP SUPPLIER
(E)	EXISTING CONSTRUCTION	FRP		OC	ON CENTER	TMB	TENANT'S MENU BOARD SUPPLIER
(N)	NEW CONSTRUCTION	FRT	FIRE RETARDANT-TREATED	OSB	ORIENTED STRAND BOARD	TMS	TENANT'S MILLWORK SUPPLIER
Ø	AT						
Ø	DIAMETER OR ROUND	GA	GAUGE	POS	POINT OF SALE	TP	TENANT'S PHONE SUPPLIER
		GALV	GALVANIZED	PREP	PREPARATION	TRS	TENANT'S RAILING SUPPLIER
AFF	ABOVE FINISH FLOOR	GC	GENERAL CONTRACTOR	PVC	POLYVINYL CHLORIDE		
ALUM	ALUMINUM	GYP	GYPSPUM			TS	TENANT'S SAFE SUPPLIER
ARCH	ARCHITECT(URAL)	HES	TENANT'S HVAC EQUIPMENT SUPPLIER	QT	QUARRY TILE	TSS	TENANT'S SMART SAFE SUPPLIER
ASS	ALARM SYSTEM SUPPLIER	HS	HOOD SUPPLIER	R	RADIUS	TSV	TENANT'S SIGN VENDOR
		HVAC	HEATING AND VENTILATING	RTU	ROOF TOP UNITS	TUV	TENANT'S UV SUPPLIER
BD	BOARD			SIM	SIMILAR	TYP	TYPICAL
BLDG	BUILDING	ICP	INITIAL COST PROJECTION	SPS	SODA POP SUPPLIER	U.N.O.	UNLESS NOTED OTHERWISE
CMU	CONCRETE MASONRY UNIT	IFP	IN FOR PERMIT	SS	SUPPORT SIGNAGE	UPS	UNINTERRUPTED POWER SUPPLY
CO2	CO2 SUPPLIER	INT	INTERIOR	STR	STRUCTURE		
CO2AS	CO2 ALARM SUPPLIER			T	TENANT		
CS	CHEMICAL SUPPLIER	KES	KITCHEN EQUIPMENT SUPPLIER	TAB	TENANT'S TEST & BALANCE VENDOR	VAR	VARIES
				TBD	TO BE DETERMINED, SEE FIELD REFERENCE MANUAL	VIF	VERIFY IN FIELD
DIM	DIMENSION(S)	MAX	MAXIMUM			W/	WITH
EA	EACH	MECH	MECHANICAL	TCC	TENANT'S CABLING CONTRACTOR	WA	WASHROOM ACCESSORIES
EL	ELEVATION (VERTICAL HEIGHT)	MFR	MANUFACTURER	TDC	TENANT'S DUCT CLEANER	WCS	TENANT'S WALK-IN COOLER SUPPLIER
ELEC	ELECTRIC(AL)	MISC	MISCELLANEOUS	TEMS	TENANT'S ENERGY MANAGEMENT SYSTEM SUPPLIER	WHS	WATER HEATER SUPPLIER
ELEV	ELEVATION	MSS	MUSIC SYSTEMS SUPPLIER			WS	TENANT'S WINDOW SHADE SUPPLIER
EQ	EQUAL			THS	TENANT'S HARDWARE SUPPLIER		
EXT	EXTERIOR	N.I.C.	NOT IN CONTRACT				

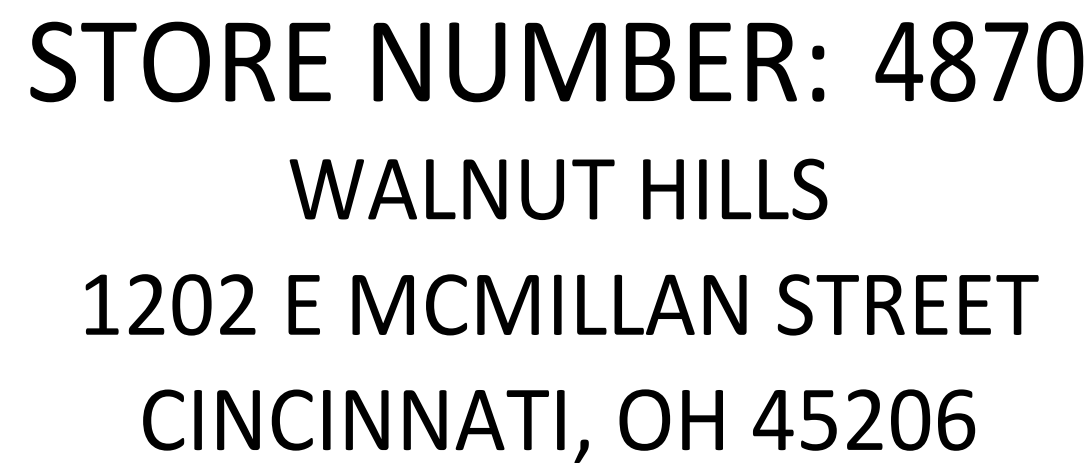

NEW FREESTANDING BUILDING		
<u>GROUP</u>	<u>TENANT</u>	<u>USE</u>
PROPOSED USE:	CHIPOTLE MEXICAN GRILL	A-2

SHELL/LANDLORD DRAWINGS: 2023P10087

A detailed key site plan for the proposed building. The plan is oriented with Victory Pkwy to the left and McMillan St at the bottom. The proposed building footprint is shown in the center, with a parking lot to its right. The parking lot contains 20 spaces, with 10 marked with 'X's. A north arrow is located in the upper right corner. A scale bar indicates 1" = 40'-0". A legend in the bottom left corner shows the symbols for 'TRUE' (a circle with a cross) and 'PLAN' (a circle with a cross and a '2' inside). The text 'AREA OF WORK' is written in the upper right corner, with an arrow pointing to the building footprint.

NOTE: THE FOLLOWING SUBCONTRACTORS ARE REQUIRED BY THE LANDLORD TO BE USED BY THE TENANT G.C. VERIFY ALL REQUIRED LANDLORD SUB-CONTRACTORS WITH LANDLORD PRIOR TO BIDDING PROJECT.

ROOFING	TBD
<u>SUBCONTRACTOR</u>	

SHEET NO.	SHEET NAME	REVISION														
		1	2	3	4	5	6	7	8	9	10	11	12	13	14	15
GENERAL																
G000	COVER SHEET		●	●												
G001	PROJECT DATA & LIFE SAFETY PLAN		●													
G002	ACCESSIBILITY REQUIREMENTS															
G010	ARCHITECTURAL SPECIFICATIONS															
G011	ARCHITECTURAL SPECIFICATIONS															
G012	ARCHITECTURAL SPECIFICATIONS															
G013	ARCHITECTURAL SPECIFICATIONS															
G014	ARCHITECTURAL SPECIFICATIONS															
G015	ARCHITECTURAL SPECIFICATIONS															
G016	ARCHITECTURAL SPECIFICATIONS															
G017	ARCHITECTURAL SPECIFICATIONS															
SITE PLAN																
SP100	ARCHITECTURAL SITE PLAN															
ARCHITECTURAL																
A101a	SLAB WORK PLAN		●													
A101b	SLAB WORK PLAN															
A110	ARCHITECTURAL FLOOR PLAN															
A120	FINISH PLAN															
A130	FF&E PLAN		●													
A131	EQUIPMENT SCHEDULE															
A132	EQUIP. & FURNITURE SCHEDULE															
A140	ARCHITECTURAL ROOF PLAN			●												
A201	REFLECTED CEILING PLAN															
A202	REFLECTED CEILING & UNISTRUT PLAN															
A210	CEILING DETAILS															
A211	LIGHTING DETAILS															
A301	EXTERIOR ELEVATIONS															
A501	ARCHITECTURAL WALL TYPES															
A502	INTERIOR SECTIONS															
A601	DOOR & HARDWARE SCHEDULE															
A701	ELEVATIONS - INTERIOR DINING															
A702	ELEVATIONS - INTERIOR KITCHEN		●													
A703	ELEVATIONS - INTERIOR KITCHEN															
A710	RESTROOM DETAILS															
A801	FINISH DETAILS															
A802	TILE DETAILS															
A900	INTERIOR PERSPECTIVES															
STRUCTURAL																
S100	SLAB PLAN															
S110	ROOF FRAMING PLAN															
S300	FRAMING DETAILS															
HVAC																
M010	HVAC SPECIFICATIONS															
M100	HVAC PLAN		●													
M600	HVAC SCHEDULES		●													
M700	HVAC DETAILS															
PLUMBING (FOR REFERENCE)																
P010	PLUMBING SPECIFICATIONS		●													
P100	PLUMBING PLAN WATER & GAS		●	●												
P110	PLUMBING PLAN WASTE & VENT		●													
P600	PLUMBING SCHEDULES															
P700	PLUMBING DETAILS			</												

WALNUT HILLS
1202 E MCMILLAN STREET
CINCINNATI, OH 45206

COVER SHEET

G000

BUILDING CODE & ZONING DATA

1.

OCCUPANCY GROUP:
OCCUPANCY SEPARATION REQUIRED:
OCCUPANCY SEPARATION PROVIDED:

A-2
N/A
N/A
2.

TYPE OF CONSTRUCTION:

V-B
3.

USE GROUP:
ALLOWABLE AREA:
AREA INCREASE W/ SPRINKLERS:
ACTUAL AREA:
TENANT LEASE AREA:

A-2
6,000 S.F.
N/A
2,384 S.F.
2,384 S.F.
4.

ALLOWABLE NO. OF STORIES:
ACTUAL NO. OF STORIES:
ALLOWABLE BUILDING HEIGHT:
ACTUAL BUILDING HEIGHT:

1
1
40'-0" MAXIMUM HEIGHT
20'-8"
5.

CALCULATED OCCUPANT LOAD
DINING ROOM AND CIRCULATION
KITCHEN-COMMERCIAL
RESTROOMS AND CIRCULATION

726 SF / 15 SF = 49
1036 SF / 200 SF = 6
156 SF / 100 SF = 2

TOTAL OCCUPANT LOAD TO BE POSTED: 99 OCC. (MAX OCCUPANCY)
THE CALCULATED OCCUPANT LOAD IS LESS THAN THE PROPOSED POSTED
OCCUPANT LOAD. ALL LIFE SAFETY AND RESTROOM CALCULATIONS ARE
BASED ON THE POSTED OCCUPANT LOAD.

SEATING:
INTERIOR: 42 SEATS
PATIO: 18 SEATS
TOTAL: 60 SEATS

6.

MEANS OF EGRESS REQUIRED:
MEANS OF EGRESS PROVIDED:

2
3

7.

FIRE SPRINKLERS:

NONE

8.

PLUMBING FIXTURES
WATER CLOSETS
REQ'D PROV'D
MEN'S: 1 1
WOMEN'S: 1 1

LAVORATORIES
REQ'D PROV'D
1 1
1 1

URINALS
REQ'D PROV'D
0 0
0 0

NOTE: RESTROOMS SHOWN AS UNISEX WITH TOTAL FIXTURE COUNTS MET.

CODE AUTHORITIES

BUILDING CODE:	2017 OHIO BUILDING CODE
EXISTING BUILDING CODE:	2017 OHIO EXISTING BUILDING CODE
MECHANICAL CODE:	2017 OHIO MECHANICAL CODE
PLUMBING CODE:	2017 OHIO PLUMBING CODE
ENERGY CODE:	2017 OHIO ENERGY CODE
FUEL GAS CODE:	2015 INTERNATIONAL FUEL GAS CODE
ELECTRICAL CODE:	2017 OHIO ELECTRIC CODE
FIRE CODE:	2017 OHIO FIRE CODE WITH LOCAL AMENDMENTS
ACCESSIBILITY:	2009 ANSI 117.1
FOOD/RESTAURANT CODE	OHIO UNIFORM FOOD SAFETY CODE 3717-1

EGRESS SEPARATION NOTE

- OVERALL DISTANCE:

66'-1"
- REQUIRED SEPARATION:

33'-1/2" (NON-SPRINKLERED)
- PROVIDED SEPARATION:

48'-9"

GENERAL NOTES PER IBC 2018

- ☒

44" REQUIRED EGRESS CORRIDOR WIDTH FOR OCCUPANCIES 50+.
42" REQUIRED EGRESS AISLE WIDTH FOR OCCUPANCIES 50 AND OVER.
36" REQUIRED EGRESS WIDTH FOR OCCUPANCIES UNDER 50.
SECT. 1029.9.1(4)
- ☒

NO DEAD END CORRIDORS OVER 20'-0"
SECT. 1020.4
- ☒

MAXIMUM EGRESS TRAVEL DISTANCE TO AN EXIT IS 75'-0". MEASURED AS MOST REMOTE POINT ALONG
THE NATURAL AND UNOBSTRUCTED PATH OF HORIZONTAL AND VERTICAL TRAVEL TO THE EXIT.
TABLE 1006.2.1
- ☒

DISTANCE BETWEEN TWO POINTS OF EGRESS (MEASURED IN A STRAIGHT LINE BETWEEN THE TWO) SHALL
NOT BE LESS THAN 1/2 DIAGONAL OF SPACE BEING SERVED FOR EGRESS PATH.
SECT. 1007.1.1
- ☐

IF FULLY SPRINKLERED DISTANCE BETWEEN TWO POINTS OF EGRESS CAN GO DOWN TO 1/3 OF DIAGONAL.
TABLE 1017.2
- ☒

MAXIMUM EXIT ACCESS TRAVEL DISTANCE 200' W/OUT SPRINKLER, 250' W/ SPRINKLER.
TABLE 1017.2
- ☒

MINIMUM DISTANCE BETWEEN SEATS IS 12" FOR A DISTANCE OF 12'-0" WITH AN ADDITIONAL 1/2" OF
WIDTH FOR EACH 1'-0" OR FRACTION THEREOF BEYOND ORIGINAL 12'-0".
SECT. 1029.13.1.1
- ☒

EGRESS ALONG SEATING IS MEASURED 19" FROM EDGE OF TABLE WHERE MOVEABLE CHAIRS ARE USED, OR
FROM THE EDGE OF A FIXED SEAT.
SECT. 1029.13.1
- ☒

DOORS IN FULLY OPEN POSITION SHALL NOT REDUCE A REQUIRED DIMENSION BY MORE THAN 7 INCHES.
LANDINGS SHALL HAVE A LENGTH MEASURED IN THE DIRECTION OF TRAVEL OF NOT LESS THAN 44 INCHES.
SECTION 1010.1.6
- ☒

DOORS, WHEN FULLY OPENED SHALL NOT REDUCE THE REQUIRED MEANS OF EGRESS WIDTH BY MORE THAN
7 INCHES. DOORS IN ANY POSITION SHALL NOT REDUCE THE REQUIRED WIDTH BY MORE THAN ONE-HALF.
SECT. 1005.7.1
- ☒

SPACE BETWEEN TWO DOORS IN A SERIES SHALL BE 48 INCHES MIN. PLUS WIDTH OF A DOOR SWINGING
INTO SPACE. DOORS IN A SERIES SHALL SWING EITHER IN THE SAME DIRECTION OR AWAY FROM THE SPACE
BETWEEN THE DOOR
SECT. 1010.1.8

Consultant:

R/A

Red Architecture

589 W. NATIONWIDE BLVD. SUITE B
COLUMBUS, OHIO 43215 (614) 487-8770

FOR
CONSTRUCTION

COPYRIGHT 2023
THIS DRAWING IS AN INSTRUMENT OF SERVICE
AND AS SUCH REMAINS THE PROPERTY OF
CHIPOTLE MEXICAN GRILL, INC.. PERMISSION FOR
USE OF THIS DOCUMENT IS LIMITED AND CAN BE
EXTENDED ONLY BY WRITTEN AGREEMENT WITH
CHIPOTLE MEXICAN GRILL, INC..



CHIPOTLE MEXICAN GRILL, INC.
PO BOX 182566
COLUMBUS, OH 43218-2566
TELEPHONE: 614.318.2400
INTERNET: WWW.CHIPOTLE.COM

STORE NO.: 4870
WALNUT HILLS
1202 E MCMILLAN STREET
CINCINNATI, OH 45206

Issue Record:

11/03/23 PERMIT SET
05/08/24 CONSTRUCTION SET

Revisions:

1 1/24/24 HEALTH COMMENTS

Drawn:

JTH,
PH

Checked:

TC


Project No.

CMG1144

Contents:

PROJECT DATA & LIFE
SAFETY PLAN

G001

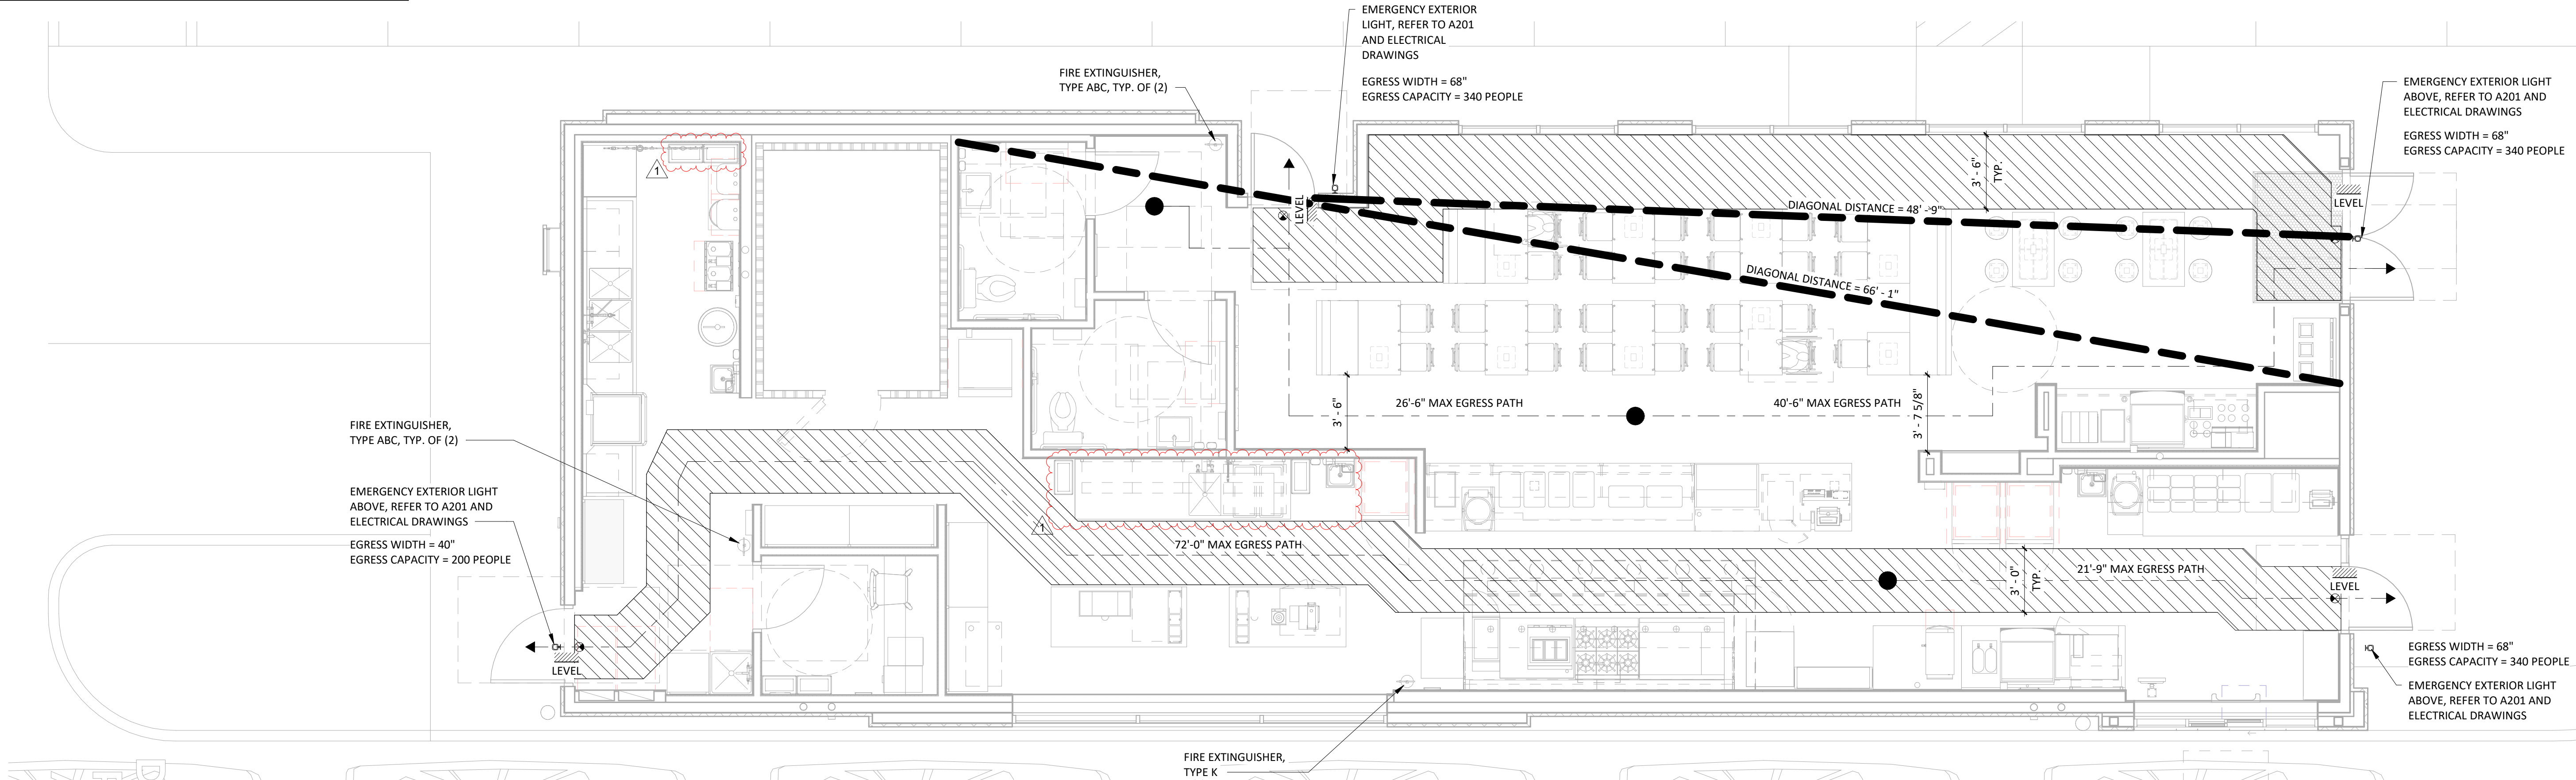

1
G001
LIFE SAFETY PLAN
1/4" = 1'-0"

DIVISION 1 - GENERAL REQUIREMENTS

SECTION 01100 - SUMMARY

- 1.1 Contract Documents:
- A. Contractor shall use the following Tenant provided documents in the negotiation and execution of the Work. Contact Tenant's office for copies of these documents:
 - 1. Chipotle Instructions to Bidders.
 - 2. Construction Contract for Chipotle Mexican Grill.
 - B. Definitions:
 - 1. The term "Owner" used in these documents refers to the building Owner/Landlord.
 - 2. The term "Tenant" used in these documents refer to the restaurant Tenant, Chipotle Mexican Grill, Inc.
 - 3. The term "Contractor" used in these documents refers to the entity responsible for performing the Work under Construction Contract for Chipotle Mexican Grill.
- 1.2 Scope of Work:
- A. The Work shall include construction of the site and building facilities as shown and specified in these Specifications and Drawings.
 - B. When required and necessary, the Tenant will provide a subsurface exploration report as an attachment the bidding documents.

SECTION 01300 - ADMINISTRATIVE REQUIREMENTS

- 1.1 Coordination:
- A. Immediately inform the Architect of discrepancies between the information indicated in the Contract Documents and existing project conditions, and of discrepancies between information indicated on the architectural, structural, mechanical, plumbing and electrical documents.
 - B. Prior to fabrication and installation of new components, field verify all existing and new dimensions and installation conditions that may affect the Work. Do not scale the drawings to establish locations of items that are not located using dimensions.
 - 1. All dimensions are to rough face of stud or centerline of structure, unless otherwise indicated.
 - 2. Verify that all Subcontractors have reviewed and coordinated locations of their equipment and furnishings exposed to view with the architectural drawings. Review questions with the Architect.
 - C. Coordinate new work indicated on the Contract Documents with new work that may be provided by the Owner and Tenant under separate contracts.
 - D. Coordinate the work of Vendors, Contractors and Subcontractors providing fixtures, furniture and equipment identified as "by Tenant" in these drawings and specifications.
 - 1. Notify the Tenant in timely fashion if any problems develop with the performance of these Vendors, Contractors or Subcontractors.
 - E. Coordinate the scheduling, sequencing, and the work of all trades and Subcontractors to assure efficient and orderly sequences of installation of interdependent construction elements.
 - F. Verify that the utility requirement characteristics of operating equipment are compatible with the building utility services. Coordinate work of the various specification sections having interdependent responsibilities for installing, connecting to, and placing in service such equipment.
 - G. Coordinate the installation and physical space requirements of plumbing, mechanical and electrical work that are indicated diagrammatically on the drawings. Follow routing shown for piping, ducts and conduit as closely as practical. Install runs parallel with and perpendicular to the line of the building. Utilize spaces as efficiently as possible to maximize accessibility for other work installation and for maintenance and for repair.
 - 1. Conceal piping, ducts and conduit within the construction, except as otherwise indicated.
 - 2. Coordinate locations of registers, fixtures and outlets with finish elements.
 - H. Coordinate completion and cleanup work of all trades and Subcontractors in preparation for Substantial Completion.
 - I. To minimize disruption of Tenant's activities after Tenant occupancy of the property, coordinate access to the property with the Tenant's Construction Manager for correction of defective work and work not in accordance with the Contract Documents.
- 1.2 Submittals:
- A. Only when indicated in the specifications or drawings submit shop drawings, product data, and/or samples to the Architect, Design Manager, and Development Analyst for review. All submittals shall be made directly to the Architect by the general contractor. Only submittals for specified products will be accepted unless prior approval has been obtained for a substitution (refer to Section 01630).
- Shop drawings: Submit electronic copies of each sheet of drawings. Shop drawings are original drawings prepared by the subcontractor or vendor for the purpose of conveying information to the Architect and/or Engineer on how a building element or product will be constructed in sufficient detail for the Architect and/or Engineer to determine compliance with the design intent.
- In all cases one copy of the submittal shall be returned to the General Contractor. Electronic submittals for shop drawing or product data in either PDF or DWG format are acceptable for review. All submittals, regardless of format, must bear the General Contractor's stamp indicating the submittal has been reviewed and approved. Any submittal not meeting the requirements set forth will be rejected by the Architect.
- Submittals shall be made with respect to the construction schedule to allow for adequate review time: allow (5) business days for review of submittals for any structural steel, canopies and trusses and allow (3) business days for review of submittals in all other divisions. Review timeline will commence from the time the submittal with General Contractor's approval stamp is received by the Architect, Design Manager, and Development Analyst.
- 1.3 Requests For Information
- A. In the event that the general contractor, or a subcontractor, at any tier, determines that some portion of the drawings, specifications, or other contract documents requires a clarification or interpretation by the architect, the general contractor shall submit a Request For Information in writing to the architect in an electronic copy.
- Requests for Information may only be submitted by the general contractor and may only be submitted to the architect. The general contractor shall clearly and concisely set forth the issue for which clarification or interpretation is sought and why a response is needed from the architect or the architect's consultants. In the Request for Information, the general contractor shall set forth an interpretation or understanding of the requirement along with an explanation of why such an understanding was reached.
- B. The architect will review all Requests for Information to determine whether they are Requests for Information within the meaning of this term. If the architect determines that the document is not a request for information, it will be returned to the general contractor, un-reviewed as to content, for re-submittal in the proper form and in the proper manner.
- Responses to Requests for Information shall be issued upon receipt, but no later than five (5) working days of receipt of the Request from the general contractor; unless the architect determines that a longer amount of time is necessary to provide an adequate response. If a longer amount of time is determined necessary by the architect, the architect will, within five (5) working days of receipt of the Request, notify the general contractor of the anticipated response time. If the general contractor submits a Request for Information on an activity with five (5) working days or less of float on the current project schedule the general contractor shall not be entitled to any time extension due to the time it takes the architect to respond to the Request provided that the architect responds within the parameters set forth above.
- C. Responses to Requests for Information from the architect will not change any requirements of the contract documents. In the event that the general contractor believes that a response to a Request For Information will cause a change to the requirements of the contract documents, the general contractor shall immediately give written notice to the architect and the tenant stating that the general contractor considers the response to be a Change Order. Failure to give such written notice immediately shall waive the general contractor's (or any subcontractor's) right to seek additional time or cost under the Administrative Requirements of these contract documents.

SECTION 01400 - QUALITY REQUIREMENTS

- 1.1 Regulatory Requirements:
- A. Perform all work in accordance with applicable local, state, and federal building codes, plumbing codes, mechanical codes, electrical codes, ordinances and rules and regulations governing food service establishments.
 - B. Comply with local, state and federal requirements governing accessibility.
 - C. Obtain all required demolition and erosion control permits required by authorities having jurisdiction.
- 1.2 Quality Control:
- A. Maintain quality control over manufacturers, suppliers, products, services, site conditions and workmanship, to produce work of specified quality.
 - B. Comply with manufacturer's instructions and applicable trade standards.
 - C. Handle, install, connect, clean, condition and adjust products in strict accordance with manufacturer's instructions and complying with specified requirements.
 - 1. Request clarification from the Architect before proceeding, where manufacturer's instructions conflict with the Contract Documents.
 - D. Comply with specified standards as a minimum quality for the Work, except when more stringent tolerances, codes or specified requirements indicate higher standards or more precise workmanship.
 - E. Perform work by persons qualified to produce workmanship of the specified quality. Secure products in place with positive anchorage devices designed, sized and installed to withstand stress, vibration, physical distortion or disfigurement.
 - F. All dimensions shall be considered "hold-to" dimensions unless indicated otherwise (e.g. minimum or maximum dimensions.)
- 1.3 Testing:
- A. Employ and pay for the services of an independent testing laboratory to perform inspections, tests and other services when required.
 - B. Include inspection and tests as indicated in the specification sections, drawings, and as required by authorities having jurisdiction.
 - 1. Test concrete in accordance with Section 03300 and drawing requirements.
 - 2. Test structural steel in accordance with Section 05110 and drawing requirements.

SECTION 01500 - TEMPORARY FACILITIES AND CONTROLS

- 1.1 Provide temporary facilities and controls as shown and specified:
- A. Codes and Standards: Provide temporary construction facilities and controls complying with all applicable local, State and Federal local laws, regulations and codes and utility company requirements.
 - B. Temporary Heating, Ventilating and Cooling:
 - 1. Provide, pay for and maintain all temporary heating, ventilating and cooling equipment and facilities required during the progress of the work to protect materials, finished work, and equipment against damage from low and high temperatures and humidity.
 - 2. Provide temporary heating, ventilating and cooling when the outside temperature and humidity is low/high enough to damage or affect in any way the performance or quality of material and product stored in the building, in any temporary storage area, or any material or product incorporated into the work.
 - 3. Provide temporary heating, ventilating and cooling when the outside temperature and humidity is low/high enough to significantly slow or hamper effectiveness of workers and to provide suitable working conditions.
 - C. Temporary Electrical Lighting and Power:
 - 1. Provide, pay for and maintain all temporary electrical service for lighting and power required during the progress of the work. Include all necessary wiring, fuses, disconnect switches, safety devices, junction boxes, panels, ground fault protections, and transformer if required. Include cost for providing temporary electric generators in the Contract Sum, if temporary electric service is not available for use during progress of the work.
 - 2. Temporary service and lighting and power items and installations shall conform to the requirements of the NFPA National Electric Code and OSHA Occupational Safety and Health Act of 1970.
 - D. Water: Provide, pay for and maintain all temporary water required during the progress of the work. Include all necessary storage tanks, piping, valves, fittings, hose and hose connections during construction and testing.
 - E. Temporary Toilets: Provide, pay for and maintain temporary toilet facilities for use by the Contractor, Contractor's employees and all Subcontractors and Subcontractors' employees. Comply with all local requirements for installation, use and maintenance of temporary toilet facilities.
 - F. Barriers and Enclosures:
 - 1. Provide temporary construction barriers in accordance with project requirements. Exercise all necessary precautions to protect adjacent properties, outside project contact limits, during progress of the work. Take special precautions to avoid damage to existing overhead and underground utilities and services owned or operated by the Owner or by public or private utility companies.
 - 2. Provide temporary weather-tight enclosures at exterior openings to provide acceptable working conditions and protection of materials and to allow for temporary heating, ventilating and cooling.
 - G. Field Office, Telephone and Email:
 - 1. Provide and maintain a temporary field office at the project site during progress of the work. A designated area within the existing building will be available for use as a temporary field office. Verify area size and location with the Tenant.
 - 2. Maintain copies of permits, approved shop drawings, specifications, addenda and record documents at field office.
 - 3. Provide temporary telephone service and internet service with email and photo capabilities to field office throughout progress of the work.
 - 4. Provide weekly photographic documentation of project progression to Tenant.
 - H. Safety and Security
 - 1. Provide and maintain all necessary safety provisions for protection and safety of the project work, workers and general public.
 - 2. Provide and maintain operable fire extinguishing devices in well-marked, accessible locations throughout the project. Provide types, quantities and locations in compliance with governing codes and ordinances.
 - 3. Provide all necessary security barriers and enclosures to protect the work and Tenant's operations from unauthorized entry of persons, vandalism and theft. Provide doors, when required, with self-closing hardware and locks.
 - I. Cleaning
 - 1. During Construction: Provide an approved on-site container for the use of all Contractors and Subcontractors for the collection of waste materials, debris and rubbish. Execute periodic cleaning to keep the work, the site and adjacent properties free from accumulations of waste materials, rubbish and windblown debris, resulting from construction operations. Remove crates and cartons in which materials, equipment, or fixtures are received to on-site containers daily.
 - a. Maintain the property in a clean and orderly condition. Remove waste materials, debris and rubbish from the site on a daily basis and dispose of at legal disposal areas away from the site.
 - 2. Dust Control:
 - a. Remove debris and rubbish from pipe chases, plenums and other similar closed or remote spaces prior to covering or enclosing the space.
 - b. Sweep and vacuum clean interior surfaces before start of surface finishing and painting. Continue cleaning on an as-needed basis until finishing and painting is completed.
 - c. Cleaning operations shall be acceptable to the Tenant's Construction Manager.

SECTION 01630 - SUBSTITUTIONS

- 1.1 General:
- A. Products, including materials, equipment and systems described in the Contract Documents establish the standards of required function, dimension, appearance, quality and performance of the Work. Base all bids on the "Standards" indicated.
 - B. Requests by the Contractor for changes in products, manufacturers, fabricators, suppliers, installers, and methods of construction required by the Contract Documents are considered requests for "substitutions." Substitutions will be considered only under the following conditions:
 - 1. The indicated "Standard" cannot be provided within the Contract Time
 - 2. The indicated "Standard" cannot receive necessary approval by the governing authority.
 - 3. A substantial advantage is offered the Owner, in terms of cost, time, energy conservation or other considerations of merit as determined by the Architect.

- C. Submit each request for substitution to the Architect. Identify the product, manufacturer, fabricator, supplier, installer or the fabrication or installation method to be replaced in each request. Identify related Specification Section and Drawing numbers. Provide documentation as directed by the Architect.
- D. Substitutions will not be considered when indicated on shop drawings or product data submittals without separate written request, when requested directly by subcontractor, manufacturer, fabricator, or supplier, or when acceptance will require substantial revision of the Contract Documents.
- E. Substitute products, manufacturers, fabricators, suppliers, and installers shall not be used for the Project without Tenant and Architect's written acceptance.

SECTION 01700 - EXECUTION REQUIREMENTS

- 1.1 Preparation:
- A. Protection of existing construction: Use all necessary care and appropriate means and methods to protect and prevent damage to existing construction and property not part of the Contract Work. Repair and refinish or replace construction an property damaged during construction work, at Contractor's expense.
- 1.2 Selective Demolition: Provide selective demolition as shown and specified.
- A. Preparation:
 - 1. Coordinate work of this Section with work of various Contractors and Tenant's staff.
 - 2. Maintain protected access at all times.
 - 3. Erect and maintain weatherproof closures at exterior openings.
 - 4. Erect and maintain dust-proof interior partitions to prevent spread of dust or fumes.
 - 5. Erect and maintain barricades, enclosures, bracing, shoring, lights, warning signs and guards necessary for worker and public safety and protection of property.
 - 6. Disconnect, remove and cap designated utility services. Identify and mark locations of disconnected and capped utilities at the project site and on Project Record Documents.
 - 7. Notify and coordinate with the Tenant's Construction Manager and the building Owner for any demolition occurring outside the lease limit.
 - 8. Coordinate hours of operation and construction access with the Tenant's Construction Manager and the building Owner.
 - B. Selective Demolition
 - 1. Remove existing construction to accommodate new construction as indicated.
 - 2. Perform selective demolition in an orderly, systematic and careful manner with least possible disturbance to public and adjacent property. Use of explosives is prohibited.
 - 3. Immediately remove from the site and legally dispose of demolished materials, except as indicated otherwise. Do not burn or bury materials on the project site.
- 1.3 Cleaning
- A. Final Cleaning: Perform final cleaning upon completion of project work.
 - 1. Remove waste and surplus materials, rubbish, tools, equipment and temporary construction facilities from the site.
 - 2. Clean exterior grounds; remove stains, spills and foreign materials from paved areas, power wash and sweep clean. Rake clean landscaped surfaces of the grounds.
 - 3. Remove temporary protection and labels not required to remain.
 - 4. Clean all finished surfaces. Remove grease, mastic, adhesives, dust, dirt, stains, fingerprints, labels and other foreign materials from exposed interior and exterior surfaces.
 - a. Clean all plumbing, fire protection and electrical fixtures and equipment including ceiling area elevated ductwork and lighting fixtures.
 - b. Clean permanent equipment filters and replace temporary disposable filters in mechanical units used during construction.
 - c. Clean ducts, blowers and coils if mechanical units were operated without filters during construction.
 - 5. Clean interior and exterior lighting and mirrors, polish transparent and glossy surfaces and clean floors with appropriate materials and equipment.
 - 6. Remove waste, foreign material and debris from roofs, areaways and drainage systems.
 - 7. Before Tenant occupancy, conduct an inspection, with the Tenant, of exposed interior and exterior surfaces at all work areas, to verify that the entire work is clean.
- 1.4 Starting and Adjusting:
- A. Prior to Substantial Completion, coordinate the start-up, test and balance, placement in operation and adjustment all systems, controls and equipment to verify proper operation. All systems shall be complete and operating prior to final inspection.
- 1.5 Contract Closeout:
- A. Operation and Maintenance Data: Submit one operation and maintenance manual, bound in 8-1/2" x 11" text pages, three D side ring capacity expansion binders with durable plastic covers.
 - 1. Subdivide the binder contents internally with permanent dividers logically organized as described below. Provide tab titles clearly printed under reinforced laminated plastic tabs.
 - 2. Provide a table of contents with each product or system description identified.
 - 3. Provide a directory listing names, addresses, and telephone numbers of the project Architect/Engineer, Contractor, Subcontractors and major equipment suppliers.
 - 4. Prepare operations and maintenance instructions arranged by system and subdivided by specification section. Identify names, addresses, and telephone numbers of project Subcontractors and suppliers. For each category, identify the following:
 - a. Significant design criteria.
 - b. List of equipment.
 - c. Parts list for each component.
 - d. Operating instructions.
 - e. Maintenance instructions for each equipment item and systems.
 - f. Maintenance instructions for special finishes, including recommended cleaning methods and materials and special precautions for identifying detrimental agents.
 - B. Submit operations and maintenance data to the Tenant with final application for payment in accordance with Exhibit C of the Construction Contract.
- B. Record/As Built Documents:
- 1. Prepare and maintain on site one set of the following record/as built documents:
 - a. Contract Documents.
 - b. Construction Documents.
 - c. Change orders and other modifications to the Contract.
 - d. Shop drawings, product data, and samples.
 - e. Construction schedule.
 - 2. Store record/as built documents separate from documents used for construction.
 - 3. Record actual revisions to the Work, concurrently with construction progress.
 - 4. Legibly mark and record a description of actual products installed at each specification section, including the following:
 - a. Manufacturer's name and product model and number.
 - b. Approved product substitutions or alternates utilized.
 - c. Changes made by addenda, change orders, and other modifications.
 - 5. Legibly mark each item to record actual construction, including the following:
 - a. Measured depths of foundations in relation to finish first main floor datum.
 - b. Measured horizontal and vertical locations of underground utilities and appurtenances, referenced to permanent surface improvements.
 - c. Measured locations of internal utilities and appurtenances concealed in construction, referenced to visible and accessible features of the work.
 - d. Field changes of dimension and detail.
 - e. Details not on original Contract Document drawings.
 - 6. Submit record/as built documents to the Tenant with final application for payment in accordance with Exhibit C of the Construction Contract.

C. Warranties and Bonds:

- 1. Compile warranties and bonds required by the Contract Documents.
 - 2. Submit duplicate copies of warranties and bonds to the Tenant with final application for payment in accordance with Exhibit C of the Construction Contract.
- D. Maintenance Materials and Spare Parts:
- 1. Provide extra maintenance materials and spare parts in quantities indicated in the specification sections.
 - 2. Place in location as directed by the Tenant's Construction Manager.

DIVISION 2 - SITE CONSTRUCTION

- 1.1 General: Provide site construction work, including services, utilities, earthwork, paving and landscaping in accordance with the site construction work drawings and details.
- 2.1 Materials:
- A. Stencils for pavement markings: Pavement Stencil Comapny, P: (800) 250-5547, stencils@pavementstencil.com

DIVISION 3 - CONCRETE

SECTION 03300 - CAST-IN-PLACE CONCRETE

- 1.1 General: Provide cast-in-place concrete work in accordance with the General Structural Notes, structural drawing and details. Follow shell building documents for specifications, joints and geotech.
- A. Standards: Materials and construction shall conform to the following:
 - 1. ACI 117 "Standard Tolerances for Concrete Construction and Materials."
 - 2. ACI 301 "Structural Concrete for Buildings."
 - 3. ACI 305R "Recommended Practice for Hot Weather Concreting."
 - 4. ACI 306R "Recommended Practice for Cold Weather Concreting."
 - 5. ACI 315 "Details and Detailing of Concrete Reinforcement."
 - 6. ACI 318 "Building Code Requirements for Reinforced Concrete."
- 2.1 Materials:
- A. Under Slab Vapor Retarder: Stego Industries LLC, 877-464-7834, internet www.stegoindustries.com high density polyethylene Stego Wrap (10 mil) Vapor Barrier meeting or exceeding ASTM E1745 performance criteria for Class C vapor retarders.
 - 1. Seam Tape: High density polyethylene tape with pressure sensitive adhesive.
 - 2. Pipe boots: Shop or site fabricated from vapor retarder material and seam tape.
 - B. Concrete:
 - 1. Portland Cement: ASTM C150, Type I
 - 2. Aggregate: ASTM C33.
 - 3. Water: Clean and potable.
 - 4. Reinforcement: When required, comply with drawings reinforcement requirements.
 - 5. Compressive Strength: Minimum 3000 psi at 28 days.
 - 6. Admixtures: All admixtures shall be approved by the Tenant's Construction Manager prior to placement in the concrete mix.
 - C. Topping Concrete: When required to suit installation conditions, Ardex Diamo-Top of Ardex Engineered Cements (888) 512-7339, internet www.ardex.com
 - 1. ULTRAFLOAR ARDEX DIAMA-TOP, self-leveling concrete repair material.
 - 2. Any pinholes that need to be filled shall be filled with ARDEX DIAMA-FILL filling compound for polished concrete, concrete terrazzo and other cementitious wear surfaces applied at the appropriate time during the polishing process.
 - 3. The primer for areas to receive ARDEX DIAMA-TOP will be ARDEX EP 2000 Substrate Preparation Epoxy.
 - 4. Installation shall be performed by factory-trained professional applicators in strict accordance with manufacturer's installation instructions.
- 3.1 Installation
- A. Vapor Retarder: Place, protect and repair vapor retarder sheets in accordance with ASTM E1643 and manufacturer's installation instructions.
 - 1. Provide a single layer of vapor retarder material over level compacted slab base.
 - 2. Lap joints and seams 6 inches and seal with seam tape.
 - 3. Seal all penetrations and repair damaged areas before concrete placement.
 - B. Reinforcement Place and inspect all reinforcing steel before concrete is placed.
 - C. Concrete Placement:
 - 1. Place cast-in-place concrete in accordance with ACI 301 and ACI 305R and 306R recommended practices for hot weather and cold weather concreting. Do not place concrete when temperature is below 40 degrees F.
 - 2. Wet cure concrete in accordance with ACI 301, using moist curing or moisture-retaining covers
 - D. Finish: Except where additional floor finish is scheduled, provide a smooth steel trowel finish.
 - 1. Exposed concrete used as a finish floor surface shall have a smooth finished surface, uniform in texture and appearance and free of trowel marks and other defects affecting ease of maintenance.
 - 2. Grind smooth surface defects as directed by the Tenant's Construction Manager.
 - E. Testing: When required, comply with drawings and specification sections testing requirements.
 - F. Topping Concrete: Prepare concrete floor slab substrate surfaces, prime substrate surfaces, mix, install and finish topping concrete in accordance with manufacturer's application instructions.

SECTION 033600 - RESINOUS FLOORING

- 1.1 General: Section includes: Decorative resinous flooring systems.
- 1.2 System Description:
- A. Performance Requirements: Provide resinous flooring that has been manufactured and installed to maintain performance criteria stated by manufacturer without defects, damage or failure.
- 1.3 Quality Assurance:
- A. Qualifications:
 - 1. Installer Qualifications: Installer experienced in performing work of this section who has specialized in installation of work similar to that required for this project.
 - a. Installer shall be an established company with at least 3 years experience in the installation of polymer floors.
 - b. Contractor shall demonstrate the ability to undertake and complete the required work and furnish documentation regarding the successful completion of projects of similar size and complexity.
 - 2. Manufacturer Qualifications: Manufacturer shall be capable of providing technical support, qualified applicators, and approval of application methods.
 - B. Pre-installation Meetings: Conduct a pre-installation meeting to verify flooring system specifications (color, texture, etc.), substrate analysis, and manufacturer's installation instructions.
 - C. Pre-installation Testing: Conduct pre-installation testing as follows:
 - 1. Water Vapor Transmission: Calcium Chloride tests should be conducted to determine the amount of water vapor coming through the slab. The results should be compared to limitations set forth by the manufacturer.
 - 2. Core Sample Testing: (optional) Core samples should be taken and analyzed if the installer believes there to be a problem with the integrity of the substrate that may affect flooring system performance.
- 1.4 Delivery, Storage & Handling:
- A. Ordering: Comply with manufacturer's ordering procedures and allow for enough lead-time for custom blends so as not to interfere with construction schedules.
 - B. Delivery: Deliver materials in manufacturer's original, unopened, undamaged containers with identification labels intact.
 - C. Storage and Protection: Store materials where they are protected from direct sunlight and harmful weather conditions. Meet manufacturer's condition for temperature, humidity, etc.
- 1.5 Project Conditions:
- A. Environmental Requirements/Conditions: Substrate and ambient air temperatures shall be in accordance with manufacturer's requirements.
 - B. Temperature Requirements: Maintain air temperature in spaces where products will be installed for time period before, during and after installation as recommended by manufacturer.

Consultant:

R/A

Red Architecture

589 W. NATIONWIDE BLVD. SUITE B
COLUMBUS, OHIO 43215 (614) 487-8770

FOR
CONSTRUCTION

COPYRIGHT 2023
THIS DRAWING IS AN INSTRUMENT OF SERVICE
AND AS SUCH REMAINS THE PROPERTY OF
CHIPOTLE MEXICAN GRILL, INC.. PERMISSION FOR
USE OF THIS DOCUMENT IS LIMITED AND CAN BE
EXTENDED ONLY BY WRITTEN AGREEMENT WITH
CHIPOTLE MEXICAN GRILL, INC..



CHIPOTLE MEXICAN GRILL, INC.
PO BOX 182566
COLUMBUS, OH 43218-2566
TELEPHONE: 614 318-2400
INTERNET: WWW.CHIPOTLE.COM

STORE NO.: 4870
WALNUT HILLS
1202 E MCMILLAN STREET
CINCINNATI, OH 45206

Issue Record:

11/03/23 PERMIT SET
05/08/24 CONSTRUCTION SET

Revisions:

Drawn:

JTH,
PH

Checked:

TC

Project No.

CMG1144

Contents:

ARCHITECTURAL
SPECIFICATIONS

G010

DIVISION 8 - DOORS AND WINDOWS

SECTION 08110 - STEEL DOORS AND FRAMES

1.1 General: Tenant to provide steel doors and frames as shown and specified.

A. Standards: Materials and construction shall conform to the following:

1. ANSI A250.8-2009 "Specifications for Standard Steel Doors and Frames."
2. ANSI A250.11-01 "Erection Instructions for Steel Frames."
3. SDI 122-99 " Installation for Standard Steel doors and Frames.

B. Manufacturer: A member of the Steel Door Institute (SDI).

2.1 Materials:

A. Steel Doors:

1. Interior: Heavy-duty Level 2, physical performance B, Model 2 seamless construction, ASTM A1008, 18 gage cold-rolled steel face sheets, manufacturer's standard core.

2. Exterior: Extra heavy-duty Level 3, physical performance A, Model 2 seamless construction, ASTM A1008, 16 gage cold-rolled steel face sheets; tops and bottoms closed with flush galvanized steel caps, manufacturer's standard plastic foam insulating core.

B. Steel Frames: ASTM A1008, 16 gage cold-rolled steel.

1. Provide combination buck, jamb and trim type frames for 1-3/4" thick doors, unless otherwise indicated.
2. Interior and exterior frames: Set-up welded type with mitered corners, reinforced, fully seam welded with exposed welds ground smooth.

C. Door and frame fabrication:

1. Provide cutouts for mortised hardware, accurately located and made to fit hardware. Provide closer reinforcement for all doors with surface mounted door closers.
2. Punch frames and factory install rubber door silencers.
3. Provide minimum three anchors of suitable design for each jamb.
4. Provide floor clip on bottom of each jamb. Provide angle spreaders at bottom of each set-up frame.

D. Shop painting: Clean and paint exposed surfaces of steel door and frame units. Apply one baked-on shop coat of rust-inhibitive prime paint in accordance with ANSI A250.10, unless doors and frames are used at the restrooms or as indicated on door hardware and finish schedule. Provide a uniformly finished surface ready to receive finish paint.

3.1 Installation:

A. Install frames plumb, level, rigid, and in true alignment as recommended in ANSI A250.11.

B. Install doors plumb and in true alignment and fastened to achieve the maximum operational effectiveness and appearance as recommended in SDI 122.

NOT USED

ENTRANCES AND STOREFRONTS

1.1 General: Provide aluminum entrances and storefronts as shown and specified.

1.2 Related Documents:

A. Drawings and general provisions of the Contract, including General and Supplementary Conditions and Division 01 Specification Sections, apply to this section.

B. Standards: Materials and construction shall conform to the following:

1. AAMA SFM-1-87 "Aluminum Storefront and Entrance Manual."

1.3 Summary:

A. Section Includes:

1. Kawneer Architectural Aluminum Storefront Systems, including perimeter trims, stools, accessories, shims and anchors, and perimeter sealing of storefront units:
 - a. Types of Kawneer Aluminum Storefront include:
 - (1) Trifab 601T Storefront System - 2" x 6" nominal dimension; Thermal; Center-Set
 - (2) Trifab VG 451T Storefront System - 2" x 4-1/2" nominal dimension; Thermal; Front-Set
2. Kawneer Aluminum Entrances, glass and glazing, and components
 - a. Types of Kawneer Aluminum Entrances include:
 - (1) 500 Swing Door; Wide stile, 5" vertical face dimension, 1-3/4" depth, high traffic applications or as indicated on Drawings.
3. Kawneer Tube for Feature Exterior Slat Wall
4. Alternate Storefront Systems only when approved by Arch PM and Chipotle DM.
 - a. YKK
 - (1) YES 60 TU Storefront System - 2" x 6" nominal dimension; Thermal
 - (2) YES 45 TU Storefront System - 2" x 4-1/2" nominal dimension; Thermal; Front-Set
 - b. Oldcastle
 - (1) Series 6000XT Storefront System - 2" x 6" nominal dimension; Thermal
 - (2) Series 3000 Thermal MultiPlane Storefront System - 2" x 4-1/2" nominal dimension; Thermal; Front-Set
 - c. US Aluminum
 - (1) Series FT601 - 2" x 6" nominal dimension; Thermal
 - (2) Series FT451 - 2" x 4-1/2" nominal dimension; Thermal; Front-Set
 - d. EFCO
 - (1) Series 406 (T) Storefront System - 2" x 6-1/2" nominal dimension; Thermal
 - (2) Series 403 (T) Storefront System - 2" x 4-1/2" nominal dimension; Thermal
 - e. Wausau
 - (1) TU24650 Storefront System - 2" x 6-1/2" nominal dimension; Thermal
 - (2) TU24000 Storefront System - 2" x 4-1/2" nominal dimension; Thermal

1.4 Performance Requirements:

A. General Performance: Aluminum-framed storefront system shall withstand the effects of the following performance requirements without exceeding performance criteria or failure due to defective manufacture, fabrication, installation, or other defects in construction;

1. Design Wind Loads: Determine design wind loads applicable to the Project from basic wind speed indicated in miles per hour, according to ASCE 7, Section 6.5, "Method 2-Analytical Procedure," based on mean roof heights above grade indicated on Drawings.
 - a. Basic Wind Speed (MPH): Determine to meet local codes listed on A000
 - b. Importance Factor: (L100)
 - c. Exposure Category (A, B, C, D): Determine to meet local codes listed on A000

B. Storefront System Performance Requirements:

1. Wind loads: Provide storefront system; include anchorage, capable of withstanding inward and outward wind load design pressures meeting local codes listed on sheet A000.
2. Air Infiltration:
 - a. Air Infiltration for storefront frame system: The test specimen shall be tested in accordance with ASTM E 283. Air infiltration rate shall not exceed 0.06 cfm/ft. sq. at a static air pressure differential of 6.24 psf.
 - b. Air Infiltration for storefront entrances: For single acting offset pivot or butt hung entrances in the closed and locked position, the test specimen shall be tested in accordance with ASTM E 283 at a pressure differential of 6.24 psf (300 PA) for single doors and 1.567 psf (75 PA) for pairs of doors. A single 3'0" x 7'0" entrance door and frame shall not exceed 0.50 cfm per square foot. A pair of 6'0" x 7'0" entrance doors and frame shall not exceed 1.0 cfm per square foot.
3. Water Resistance: The test specimen shall be tested in accordance with ASTM E 331. There shall be no leakage at a minimum static air pressure differential of 8 psf as defined in AAMA 501.
4. Uniform Load: A static air design load of 20 psf shall be applied in the positive and negative direction in accordance with ASTM E 330. There shall be no deflection in excess of 1/175 of the span of any framing member. At a structural test load equal to 1.5 times the specified design load, no glass breakage or permanent set in the framing members in excess of 0.2% of their clear spans shall occur.
5. Thermal Transmittance (U-Factor): When tested to AAMA Specification 1503, the thermal transmittance (U-factor) shall be not more than:
 - a. Glass to Exterior - 0.47 (low-e)
6. Condensation Resistance (CRF): When tested to AAMA Specification 1503, the condensation resistance factor shall not be less than:
 - a. Glass to Exterior - 70 frame and 69 glass (low-e)
7. Sound Transmission Class (STC) and Outdoor-Indoor Transmission Class (OITC): When tested to AAMA Specification 1801 and in accordance with ASTM E1425 and ASTM E90, the STC and OITC Rating shall not be less than:
 - a. Glass to Exterior - 38 (STC) and 31 (OITC)

1.5 Submittals:

A. Product Data: Include construction details, material descriptions, dimensions of individual components and profiles, hardware, finishes, and installation instructions for each type of aluminum frame storefront system and storefront entrance doors indicated.

B. Shop Drawings: Include plans, elevations, sections, details, hardware, and attachments to work, operational clearances and installation details.

C. Samples for Initial Selection: For units with factory-applied color finishes including samples of hardware and accessories involving color section.

1.6 Quality Assurance

A. Installer Qualifications: An installer which has had successful experience with installation of the same or similar units required for the project and other projects of similar size and scope

B. Manufacturer Qualifications: A manufacturer capable of providing aluminum framed storefront system that meet or exceed performance requirements indicated and of documenting this performance by inclusion of rest reports, and calculations.

C. Source Limitations: Obtain aluminum framed storefront system and storefront entrance doors through one source from a single manufacturer.

D. Product Options: Drawings indicate size, profiles, and dimensional requirements of aluminum framed storefront system and are based on the specific system indicated. Do not modify size and dimensional requirements.

1. Do not modify intended aesthetic effects, as judged solely by Architect, except with Architect's approval. If modifications are proposed, submit comprehensive explanatory data to Architect for review.

1.7 Project Conditions:

A. Field Measurements: Verify actual dimensions of a aluminum framed storefront openings by field measurements before fabrication and indicate field measurements on Shop Drawings.

1.8 Warranty

A. Manufactures Warranty: Submit, for Owner's acceptance, manufacturer's standard warranty.

1. Warranty Period: Two (2) years from Date of Substantial Completion of the project provided however that the Limited Warranty shall begin in no event later than six months from date of shipment by manufacturer.

2.1 Manufacturers:

A. Manufacturer: Kawneer Company Inc., Contact: Doug Hess, Phone: 317-771-9265; email:doug.hess@arconic.com

1. Basis-of-Design Product Storefront Framing:
 - a. Trifab 601T (thermal) Storefront System
 - i. 2" x 6" System Dimensions
 - ii. Glass: Exterior (Center-Set)
 - b. Trifab 451T (thermal) Storefront System
 - i. 2" x 4-1/2" System Dimensions
 - ii. Glass: Exterior (Front-Set)
2. Basis-of-Design Product Storefront Entrances:
 - a. The door stile and rail face dimensions of the 500-Wide Stile entrance door will be as follows or as indicated on Drawings: Door: 500; Vertical Stile: 5"; Top Rail: 5"; Bottom Rail: 10"
 - b. Major portions of the door members to be 0.125" nominal in thickness and glazing molding to be 0.05" thick.
 - c. Glazing gaskets shall be either EPDM elastomeric extrusions or a thermoplastic elastomer.
 - d. Provide adjustable glass jacks to help center the glass in the door opening.
3. Basis-of-Design Product Feature Exterior Slat Wall:
 - a. Kawneer Tube #027881 (1" x 3"), capped at top and bottom
 - i. Alternate Exterior Slat Wall only when approved by Arch PM and Chipotle DM.
 1. Architechural Fabrication
- B. Alternate Storefront Systems only when approved by Arch PM and Chipotle DM.
 - a. YKK
 - a. YES 60 TU Storefront System - 2" x 6" nominal dimension; Thermal
 - b. YES 45 TU Storefront System - 2" x 4-1/2" nominal dimension; Thermal; Front-Set
 2. Oldcastle
 - a. Series 6000XT Storefront System - 2" x 6" nominal dimension; Thermal
 - b. Series 3000 Thermal MultiPlane Storefront System - 2" x 4-1/2" nominal dimension; Thermal; Front-Set
 3. US Aluminum
 - a. Series FT601 - 2" x 6" nominal dimension; Thermal
 - b. Series FT451 - 2" x 4-1/2" nominal dimension; Thermal; Front-Set
 4. EFCO
 - a. Series 406 (T) Storefront System - 2" x 6-1/2" nominal dimension; Thermal
 - b. Series 403 (T) Storefront System - 2" x 4-1/2" nominal dimension; Thermal
 5. Wausau
 - a. TU24650 Storefront System - 2" x 6-1/2" nominal dimension; Thermal
 - b. TU24000 Storefront System - 2" x 4-1/2" nominal dimension; Thermal

2.2 Materials:

A. Provide aluminum entrances and storefront matching the existing building aluminum entrances and storefronts, unless otherwise indicated.

B. Aluminum Frame Extrusions: Alloy and temper recommended by aluminum storefront manufacturer for strength, corrosion resistance, and application of required finish and not less than 0.070" wall thickness at any location for the main frame and complying with ASTM B 221: 6063-T6 alloy and temper.

C. Aluminum Storefront Entrance Extrusions: Alloy and temper recommended by aluminum-framed glass door manufacturer for strength, corrosion resistance, and application of required finish and not less than 0.090" wall thickness at any location for the main frame and sash members.

D. Fasteners: Aluminum, nonmagnetic stainless steel or other materials to be non-corrosive and compatible with aluminum window and door members, trim hardware, anchors, and other components.

E. Anchors, Clips, and Accessories: Aluminum, nonmagnetic stainless steel, or zinc-coated steel or iron complying with ASTM B 633 for SC 3 severe service conditions, or other suitable zinc coating; provide sufficient strength to withstand design pressure indicated.

F. Reinforcing Members: Aluminum, nonmagnetic stainless steel, or nickel/chrome-plated steel complying with ASTM B 456 for Type SC 3 severe service conditions, or zinc-coated steel or iron complying with ASTM B 633 for SC 3 severe service conditions or other suitable zinc coating; provide sufficient strength to withstand design pressure indicated.

G. Sealant: For sealants required within fabricated storefront system, provide permanently elastic, non-shrinking, and non-migrating type recommended by sealant manufacturer for joint size and movement.

H. Tolerances: Reference to tolerances for wall thickness and other cross-section dimensions of storefront members are nominal and in compliance with AA Aluminum Standard Data.

2.3 Storefront Framing System:

A. Thermal Barrier: Thermal Break shall be designed in accordance with AAMA TIR-A8 and tested in accordance with AAMA 505.

1. Kawneer IsoLock Thermal Break with a 1/4" separation consisting of a two-part chemically curing, high-density polyurethane, which is mechanically and adhesively joined to aluminum storefront sections.

B. Brackets and Reinforcements: Manufacturer's standard high-strength aluminum with non-staining, nonferrous shims for aligning system components.

C. Fasteners and Accessories: Manufacturer's standard corrosion-resistant, non-staining, non-bearing fasteners and accessories compatible with adjacent materials. Where exposed shall be stainless steel.

D. Perimeter Anchors: When steel anchors are used, provide insulation between steel material and aluminum material to prevent galvanic action.

E. Packing, Shipping, Handling and Unloading: Deliver materials in manufacturer's original, unopened, undamaged containers with identification labels intact.

F. Storage and Protection: Store materials protected from exposure to harmful weather conditions. Handle storefront material and components to avoid damage. Protect storefront material against damage from elements, construction activities, and other hazards before, during and after storefront installation.

2.4 Glazing Systems:

A. Glazing: As specified in Section 08800 - Glazing.

B. Glazing Gaskets: Manufacturer's standard compression types; replaceable, extruded EPDM rubber.

C. Spacers and Setting Blocks: Manufacturer's standard elastomeric type.

D. Bond-Breaker Tape: Manufacturer's standard TFE-fluorocarbon or polyethylene material to which sealants will not develop adhesion.

E. Glazing Sealants: For structural-sealant-glazed systems, as recommended by manufacturer for joint type, and as follows:

1. Structural Sealant: ASTM C 1184, single-component neutral-curing silicone formulation that is compatible with system components with which it comes in contact, specifically formulated and tested for use as structural sealant and approved by a structural-sealant manufacturer for use in aluminum-framed systems indicated.
 - a. Color: Black
2. Weatherseal Sealant: ASTM C 920 for Type S, Grade NS, Class 25, Uses NT, G, A, and O; single-component neutral-curing formulation that is compatible with structural sealant and other system components with which it comes in contact; recommended by structural-sealant, weatherseal-sealant, and aluminum-framed-system manufacturers for this use.
 - a. Color: Matching structural sealant.

2.5 Entrance Door Systems:

A. Entrance Door Hardware: As specified in Section 08710 Door Hardware.

2.6 Accessory Materials:

A. Joint Sealants: For installation at perimeter of aluminum-framed systems, as specified in section 07900 - Joint Sealers

2.7 Storefront Framing Fabrication:

A. Framing Members, General: Fabricate components that, when assembled, have the following characteristics:

1. Profiles that are sharp, straight, and free of defects or deformations.
2. Accurately fit joints; make joints flush, hairline and weatherproof.
3. Means to drain water passing joints, condensation within framing members, and moisture migrating within the system to exterior.
4. Physical and thermal isolation of glazing from framing members.
5. Accommodations for thermal and mechanical movements of glazing and framing to maintain required glazing edge clearances.
6. Provisions for field replacement of glazing.
7. Fasteners, anchors, and connection devices that are concealed from view to greatest extent possible.

B. Mechanically Glazed Framing Members: Fabricate for flush glazing without projecting stops.

C. Structural-Sealant-Glazed Framing Members: Include accommodations for using temporary support device to retain glazing in place while structural sealant cures.

D. Storefront Framing: Fabricate components for assembly using manufacturers standard installation instructions.

E. After fabrication, clearly mark components to identify their locations in Project according to Shop Drawings.

2.8 Storefront Entrance Door Fabrication:

A. Fabricate aluminum-framed glass entrance doors in sizes indicated. Include a complete system for assembling components and anchoring doors.

B. Fabricate aluminum-framed glass doors that are reglazable without dismantling perimeter framing.

1. Door corner construction shall consist of mechanical clip fastening, SIGMA deep penetration plug welds and 1-1/8" long fillet welds inside and outside of all four corners. Glazing stops shall be hook-in-type with EPDM glazing gaskets reinforced with non-stretchable cord.
2. Accurately fit and secure joints and corners. Make joints hairline in appearance.
3. Prepare components with internal reinforcement for door hardware.
4. Arrange fasteners and attachments to conceal from view.

C. Weather Stripping: Provide weather stripping locked into extruded grooves in door panels or frames as indicated on manufactures drawings and details.

2.9 Aluminum Finishes:

A. Finish designations prefixed by AA comply with the system established by the Aluminum Association for designating aluminum finishes.

B. Factory Finishing:

1. Kawneer Permafluor (70% PVDF), AAMA 2605, Fluoropolymer Coating (Color: Charcoal or as noted on Drawings)
2. Finishing for alternate storefront specifications to be verified by Arch PM and Chipotle DM
 - a. YKK "Charcoal" UC99477, Superior Painted Finishes
 - b. All others to be verified with samples and submittals to Arch PM

2.10 Brake Metal Trim:

A. Shop Drawings: Show layout and elevations, dimensions and thickness of panels, connections, details and location of joints, sealants and gaskets, method of anchorage, number of anchors, supports, reinforcement, trim, flashings, and accessories.

1. Show actual field measurements on shop drawings.
2. Differentiate between shop and field fabrication.
3. Indicate substrates and adjacent work with which the fabrications must be coordinated.
4. Include large-scale details of anchorages and connecting elements.
5. Include large-scale or schematic exploded or isometric diagrams to fully explain flashing at a scale of not less than 1-1/2 inches per 12 inches (1:10)

2.11 Formed Metal Fabrications - General:

A. Shop assembly: Preassemble items to greatest extent possible. Minimize field splices and field assembly. Disassemble only as necessary for transportation and handling. Mark items clearly for assembly and installation.

B. Coordination: Match dimensions and attachment of formed metal items to adjacent construction. Produce integrated assemblies. Closely fit joints; align edges and flat surfaces unless indicated otherwise.

C. Forming: Profiles indicated. Maximize lengths. Fold exposed edges to form hem indicated or ease edges to radius indicated with coealed stiffener. Provide flat, flush surfaces without cracking or grain separation at bends.

D. Reinforcement: Increase metal thickness; use concealed stiffeners, backing materials or both. Provide stretcher leveled standard of flatness and stiffness required to maintain flatness and hold adjacent items in flush alignment.

E. Anchors: Straps, plates and anchors as required to support and anchor items to adjacent construction.

F. Supports: Miscellaneous framing, mounting, clips, sleeves, fasteners and accessories required for installation.

G. Welding and brazing: Weld or braze joints continuously. Grind smooth, fill or dress to produce smooth, flush, exposed surfaces. Do not discolor metal. Grind Smooth, polish, and restore damaged finishes to required condition.

1. Ease exposed edges to small uniform radius.
2. Welded joints
 - a. Carbon Steel: Perform welding in accordance with AWS D1.1/D1.1M.
 - b. Stainless Steel: Perform welding in accordance with AWS D1.6/D1.6M
3. Brass/Bronze Brazed Joints:
 - a. Perform torch brazing in accordance with AWS C3.4M/C3.4
 - b. Perform induction brazing in accordance with AWS C3.5M/C3.5
 - c. Perform resistance brazing in accordance with AWS C3.9M/C3.9

H. Performance requirements;

1. Thermal Movements:
 - a. Allow for thermal movements in exterior metal fabrications due to temperature changes. Prevent buckling, opening of joints, overstressing of components, failure of connections, and other detrimental effects.
 - b. Temperature Change Range: 120 degrees F (67 degrees C), ambient; 180 degrees F (100 degrees C), on material surfaces.
2. Corrosion: Prevent galvanic action and other forms of corrosion by isolating metals and other materials from direct contact with incompatible materials.

2.12 Formed Metal Fabrications - Sheet Metal

A. Closures, Trim, and Fill Panels:

1. Form Closures from type and thickness of metal indicated.
2. Conceal fasteners when possible.
3. Drill and tap holes for securing to other surfaces.
4. Provide gaskets where indicated or needed for continuous seal at adjacent surfaces.
5. Miter or cope at corners and reinforce with bent metal plate. Form tight joints.

2.13 Materials

A. General: Provide sheet metal without pitting, seam marks, roller marks, stains, discolorations, or other imperfections exposed to view on finished units.

B. Galvanized Steel Sheet: ASTM A653/A653M, G90 (Z275) coating. 14 gauge min. thick base material.

C. Anchors, Clips, and Accessories: Use one of the following:

1. Stainless steel complying with ASTM A276/A276M, ASTM A480/A480M, or ASTM A666.
2. Steel complying with ASTM A36/A36M and hot-dipped galvanized to ASTM A153/A153M.
3. Steel complying with ASTM A36/A36M and hot-dipped galvanized to ASTM A123/A123M Coating Grade 35
4. Interior locations: Carbon steel; zinc coated in accordance with ASTM B633 or ASTM F1941/F1941M, Class Fe/Zn 5.
5. Exterior Locations or in contact with Stainless Steel:
 - a. Bolts: Stainless steel; ASTM F593, Group 1 (A1)
 - b. Nuts: Stainless steel; ASTM F594.
6. Structural Anchors: Provide anchors where work is indicated to comply with design loads.
 - a. Type: Provide chemical or torque controlled expansion anchors.
 - b. Capacity: When tested according to ASTM E488/E488M; four times the load imposed when installed in concrete.
7. Nonstructural Anchors: Provide powder-actuated fasteners where work is not indicated to comply wit design loads. Provide size and number required for load, installation, and as recommended by manufacturer, unless indicated otherwise.

D. Fasteners, General: Same basic metal and alloy as formed metal sheet unless indicated otherwise. Do not use metals incompatible with the materials joined.

E. Gaskets: As required to seal joints in decorative formed metal and remain airtight; as recommended in writing by decorative formed metal manufacturer.

2.14 Finishes

A. Finishes, General: Comply with NAAMM AMP 500-Q6

1. Complete mechanical finishes before fabrication. After fabrication, finish joints, bends, abrasions and surface blemishes to match sheet.
2. Protect mechanical finishes on exposed surfaces from damage.
3. Apply organic and anodic finishes to formed metal after fabrication unless indicated otherwise.
4. Appearance: Limit variations in appearance of adjacent to one-half the range represented in approved samples. noticeable variations in the same piece are not acceptable. Install components in the range of approved samples to minimize contrast.

B. Galvanized Steel Finishes:

1. Repair Galvanized Surfaces: Clean welds and abraded areas and repair galvanizing to comply with ASTM A780/A780M
2. Color: As shown on the drawings.
3. Factory Prime: Apply shop primer to prepared surfaces of items where field painting after installation indicated, unless indicated otherwise. Comply with requirements in SSPC-PA1
4. High Performance Organic Coatings: AAMA 2604; multiple coats, thermally cured fluoropolymer system.

3.1 Examination:

A. Examine openings, substrates, structural support, anchorage, and conditions, with Installer present, for compliance with requirements for installation tolerances and other conditions affecting performance of work. Verify rough opening dimensions, levelness of sill plate and operational clearances. Examine wall flashings, vapor retarders, water and weather barriers, and other built-in components to ensure a coordinated, weather tight framed aluminum storefront system installation.

1. Masonry Surfaces: Visibly dry and free of excess mortar, sand, and other construction debris.
2. Wood Frame Walls: Dry, clean, sound, well nailed, free of voids, and without offsets at joints. Ensure that nail heads are driven flush with surfaces in opening and within 3 inches of opening.
3. Metal Surfaces: Dry; clean; free of grease, oil, dirt, rust, corrosion, and welding slag; without sharp edges or offsets at joints.
4. Proceed with installation only after unsatisfactory conditions have been corrected.

3.2 Installation:

A. Comply with Drawings, Shop Drawings, and manufacturer's written instructions for installing aluminum framed storefront system, aluminum swing storefront entrance doors, accessories, and other components.

B. Install aluminum framed storefront system and storefront doors level, plumb, square, true to line, without distortion or impeding thermal movement, anchored securely in place to structural support, and in proper relation to wall flashing and other adjacent construction.

C. Set sill members and door threshold in bed of sealant or with gaskets, as indicated, for weather tight construction.

D. Install aluminum framed storefront system and components to drain condensation, water penetrating joints, and moisture migrating within sliding door to the exterior. Refer to section 07900 - Joint Sealers.

E. Separate aluminum and other corrodible surfaces from sources of corrosion or electrolytic action at points of contact with other materials.

F. Install aluminum storefront framing system glass and glazing, in accordance with section 08800 and the manufacturer's requirements.

3.3 Adjusting, Cleaning, and Protection:

A. Clean aluminum surfaces immediately after installing aluminum framed storefronts. Avoid damaging protective coatings and finishes. Remove excess sealants, glazing materials, dirt, and other substances.

B. Clean glass immediately after installation. Comply with glass manufacturer's written recommendations for final cleaning and maintenance. Remove nonpermanent labels, and clean surfaces.

C. Remove and replace glass that has been broken, chipped, cracked, abraded, or damaged during construction period.

NOT USED

1.1 General: Provide door hardware as shown and specified.

A. Standards: Materials and installation shall conform to the following:

1. ASTM A240 - Heat-Resisting Chromium and Chromium-Nickel Stainless Steel Plate, Sheet, and Strip for Pressure Vessels.
2. ASTM A653 - Steel Sheet, Zinc-Coated (Galvanized) or Zinc-Iron Alloy-Coated (Galvannealed) by the Hot-Dip Process.
3. ASTM B209 - Aluminum and Aluminum-Alloy Sheet and Plate.
4. ASTM B221 - Aluminum and Aluminum-Alloy Extruded Bars, Rods, Wire, Profiles, and Tubes.
5. ASTM B580 - Standard Specification for Anodic Oxide Coatings on Aluminum.
6. ASTM B680 - Standard Test Method for Seal Quality of Anodic Coatings on Aluminum by Acid Dissolution.
7. ASTM C1048 - Heat-Treated Flat Glass-Kind HS, Kind FT Coated and Uncoated Glass.
8. ASTM C1172 - Standard Specification for Laminated Architectural Flat Glass.
9. ASTM E774 - Standard Specification for Sealed Insulating Glass Units.
10. Aluminum Association AA DAF-45 - Designation System for Aluminum Finishes.

B. Quality Assurance:

1. Manufacturer Qualifications: Minimum of 25 years successful experience continuously manufacturing pass-thru windows.
2. Installer Qualifications: Installer shall have five years experience manufacturing and fabricating windows of similar type and scope as those specified in this section.

2.1 Materials:

A. Acceptable Manufacturers. Arch PM to verify required manufacturer per Tenant's assignment.

1. Quikserv; Toll Free: 1.800.388.8307; Email: sales@quikserv.com; Web: https://www.quikserv.com/
2. ReadyAccess; Toll Free: 1.800.621.5045; Email: ready@ready-access.com; Web: https://www.ready-access.com

B. No substitutions allowed. Requirements for manufacturer, design, grade, function, finish, size and other distinctive qualities of each type of door hardware are indicated on the drawings.

Consultant:

R/A

RedArchitecture

589 W. NATIONWIDE BLVD. SUITE B
COLUMBUS, OHIO 43215 (614) 487-8770

FOR CONSTRUCTION

Copyright 2023
THIS DRAWING IS AN INSTRUMENT OF SERVICE
AND AS SUCH REMAINS THE PROPERTY OF
CHIPOTLE MEXICAN GRILL, INC. PERMISSION FOR
USE OF THIS DOCUMENT IS LIMITED AND CAN BE
EXTENDED ONLY BY WRITTEN AGREEMENT WITH
CHIPOTLE MEXICAN GRILL, INC..

CHIPOTLE
MEXICAN GRILL

CHIPOTLE MEXICAN GRILL, INC.
PO BOX 182566
COLUMBUS, OH 43218-2566
TELEPHONE: 614.438.2400
INTERNET: WWW.CHIPOTLE.COM

STORE NO.: 4870
WALNUT HILLS
1202 E MCMILLAN STREET
CINCINNATI, OH 45206

Issue Record:

11/03/23
05/08/24

PERMIT SET
CONSTRUCTION SET

Revisions:

Drawn: JTH, PH

Checked: TC

Project No.
CMG1144

Contents:

ARCHITECTURAL SPECIFICATIONS

G014

2.2 In-Line Side Sliding Automatic Window and Air Curtain

- A. Standard Custom Side Sliding Windows – Arch PM to verify manufacturer with Tenant.

* Quikserv Custom Automatic Side Sliding Window (Model: SST-4035E-CHIPOTLE): 45 -1/2"W x 41-3/4"H window with 17-3/4" tall transom and (2) sidelights at 29 1/4"W x 41-3/4"H; Complete Unit Size 104"W x 59-1/2"H

1. Service Opening: 19"W x 29-3/4"H
2. Finish: Dark Bronze Anodized
3. Glass: 1" Clear Tempered unit + Low E (Solarban 60e) for fixed and moving panel, sidelights and transom
4. 'CHIPOTLE' package includes pre-wired air curtain with relay to sync operation with window.
a. Arch PM to verify if heated or ambient air curtain is required per Tenant assignment. Air Curtain mounts to transom.
i. Heated Air Curtain: Model: QSV1025EJ-040-BK
ii. Ambient Air Curtain: Model: QSK1025AA-BK
5. Refer to interior elevations (A700s) for direction of opening for ordering.

* ReadyAccess Automatic Side Sliding Window: 47 -1/2"W x 43-1/2"H window with 16" tall transom and (2) sidelights at 28 1/4"W x 59-1/2"H; Complete Unit Size 104"W x 59-1/2"H

1. Service Opening: 19"W x 35"H
2. Finish: Dark Bronze Anodized
3. Glass: 3/4" Clear Tempered unit + Low E (Solarban 70XL) for fixed & moving panel, sidelights and transom
4. Arch PM to verify if heated or ambient air curtain is required per Tenant assignment.
a. Heated Air Curtain: Model: AA300 (replaces transom)
b. Ambient Air Curtain: Model: AA100 (split transom)
5. Refer to exterior elevations (A300s) for direction of opening for ordering.

- B. Alternate California Code Option

1. ReadyAccess: Window 47-1/2" W x 35-3/4"H with double-split transom for air curtain and 10" and (2) sidelights at 28-1/4"W x 59-1/2"H; Complete Unit Size 104"W x 59-1/2"H
a. Service Opening:15-1/4"W x 28"H, limited to meet CA code.
b. Ambient Air Curtain, AA100, and relay switch kit included with the West Coast Window package.

2. Quikserv Model: SS-4035-E-CHIPOTLE-CALI, same as above except as noted.
a. Service Opening: 28"W x 15-3/8"H, limited to meet CA code.
b. 'CHIPOTLE' package includes pre-wired ambient air curtain with relay to sync operation with window Model: QSK1025AA-BK. Air curtain mounts to transom.

- C. Alternate Impact-Resistant and Florida Product Approved Option, Miami Dade Horizontal Bi-Parting Impact Slider

1. Quikserv Model: BP-7241E-IP-CHIPOTLE, Complete Unit Size: 72"W x 41"H.
a. Service Opening: 29-1/2"W x 27"H
b. Rough Opening: 72-1/2"W x 41-1/2"H
c. Glass: Impact Resistant Glass
d. 'CHIPOTLE' package includes ambient air curtain
i. Ambient Air Curtain: Model: QSK1025AA-BK, Part Number: 9345.
ii. Do not mount directly to window, mount on wall above.
e. Miami-Dade NOA #18-0814.02

2.3 Electrical Requirements

- A. Quikserv Electrical Windows: 120V / 60 Hz, 20-amp branch circuit, single phase. Power supplied through base of window. Conforms to UL Standard 325 – Certified to CAN/CSA C22.2 NO. 247. Confirm with Electrical Drawings.

1. Heated Air Curtain for Custom Side Sliding Window (Model: SS-4035-E-CHIPOTLE)
a. Separate 230V circuit and Power Supply required for heated air curtain. Air curtain pre-wired through window frame with power supply routed to base of window. Confirm with Electrical Drawings.
2. Ambient Air Curtain for Custom Side Sliding Window (Model: SS-4035-E-CHIPOTLE) and Alternate California Code Option: Model: SS-4035-E-CHIPOTLE-CALI
a. Separate circuit not required. Window pre-wired to power and sync operation with air curtain.
3. Ambient Air Curtain for Alternate Impact-Resistant and Florida Product Approved Option (Model: BP-7241E-IP-CHIPOTLE):
a. Connect to main control board on window to power and synchronize operation with opening and closing of window.

- B. ReadyAccess Electrical Windows: 115V / 60 Hz, 15-amp dedicated circuit required. Run power to header on fixed panel side.

1. AA300 Heated Air Curtain
a. Separate 208V /60 Hz /40-amp single phase circuit required.
2. AA100 Ambient Air Curtain (Standard and CA window)
a. Separate 120V / 60Hz / 15-amp single phase circuit required. Run power to center of window above header.

3.1 Installation

- A. Install in accordance with manufacturer's instructions.
B. Install pass-thru windows plumb, level, square, true to line, and without warp or rack. Maintain dimensional tolerances and alignment with adjacent Work.
C. Install thermal isolation where components penetrate or disrupt building insulation. Pack fibrous insulation in shim spaces at perimeter of assembly to maintain continuity of thermal barrier.
D. Install pass-thru window components weathertight.
E. Anchor pass-thru windows securely in place to supports. Use attachment methods permitting adjustment for construction tolerances, irregularities, alignment, and expansion and contraction.
F. Separate aluminum from other metal surfaces with bituminous coatings or other means approved by Architect.
G. Coordinate installation of related sheet metal flashing as specified in Section 07 62 00 - Sheet Metal Flashing and Trim.
H. Install perimeter joint sealants as specified in Section 07 91 23 - Backer Rods.

SECTION 08710 - DOOR HARDWARE

- 1.1 General: Provide door hardware as shown and specified.

- A. Standards: Materials and installation shall conform to the following:
1. ANSI A117.1:2009 Accessible and Usable Buildings and Facilities.
2. ANSI/BHMA A156 Series Builders Hardware

- B. Quality Assurance:
1. Codes and standards: Provide hardware complying with local Building Code requirements and the Tenant's standards for keying and security systems.
2. Project scheduling: Performed by an Architectural Hardware Consultant (AHC).
3. Package each item of hardware and each lockset, complete with all screws, anchors, installation instructions and templates. Identify package indexing with corresponding item number of the hardware schedule.
4. After hardware schedule acceptance, provide necessary templates or physical hardware to required trades for cutting, reinforcing, or preparing their products to receive hardware. Furnish templates to metal door manufacturer's.

- 2.1 Materials:

- A. No substitutions allowed. Requirements for manufacturer, design, grade, function, finish, size and other distinctive qualities of each type of door hardware are indicated on the drawings.

- B. Review the keying system with the Tenant and provide the type required.

- 3.1 Installation

- A. Install each hardware item in strict accordance with manufacturer's installation instructions and recommendations. Securely fasten all attached parts. Fit faces of mortised parts snug and flush. Verify operating parts move freely and smoothly without binding or sticking, without excessive clearance.

- B. Set units level, plumb and true to line and location. Adjust and reinforce attachment substrate as required for proper installation and operation. Drill and countersink units that are not factory prepared for anchorage fasteners. Space fasteners and anchors in accordance with industry standards.

- C. Mount hardware units at heights indicated in DHI "Recommended Locations for Builders Hardware", unless otherwise required to comply with requirements of governing codes and regulations. Conform to ANSI A117.1 and ADAGG guidelines for accessibility.
1. Top Butts: 5 inches; top of butt from head of frame.
2. Middle Butts: 3'-2", centerline from finish floor.
3. Bottom Butts: 5 inches; finish floor to bottom of butt.
4. Locks: centerline from finish floor per hardware schedule.
5. Knobs: 3'-2", centerline from finish floor.
6. Pulls: centerline from finish floor per hardware schedule.
7. Pushes: centerline from finish floor per hardware schedule.

NOT USED

- 1.1 General: Provide glass and glazing as shown and specified.

- A. Standards: Materials and installation shall conform to the following:
1. CPSC 16 CFR Part 1201 (1-91)"Safety Standard for Architectural Glazing Materials."
2. GANA "Glazing Manual" - 1990."
B. Quality Assurance:
1. Codes and standards: Provide type of glass and glazing products that comply with ANSI Z97.1 and testing requirements of 16 CFR Part 1201 for category II materials. Comply with all applicable codes, standards and regulations that control safety glazing materials and installation.
2. System Performance: Provide glass and glazing that has been produced, fabricated and installed to withstand normal thermal movement, wind loading and, where applicable, impact loading, without failure including loss or breakage of glass, failure of glazing sealants or gaskets to remain watertight and airtight, deterioration of glass and glazing materials and other defects in the work.
3. Installation: Performed only by experienced glaziers.

- C. Warranty:
1. Insulating glass: Five years from date of installation against defects that materially obstruct vision through the glass or affect thermal and physical integrity.

- 2.1 Materials:

- A. Glass:
1. Float Glass (FG): 1/4" thick clear float glass.
2. Tempered Glass (TG): 1/4" and 1/2" thick clear, tempered safety glass, free-of-tong marks.
3. Insulating Glass (IG): 1" thick clear, low-e tempered sealed glass; 1/4" thick interior and exterior glass lites with 1/2" aluminum desicated dual sealed air space; with the following characteristics:
a. Low-emissivity coating on #2 surface.
b. Visible Light Transmittance: 64% - 70%
c. Visible Light Reflectance - Outdoors: 9%-11%
d. Solar Energy Transmittance: 32%-34%
e. Solar Energy Reflectance-Outdoors: 30%-34%
f. U-Value - Winter Night: 0.29
g. U-value - Summer days: 0.28
h. Solar Heat gain Coefficient: 0.25-0.39
i. Shading Coefficient: 0.43-0.45
j. Manufacturers/Products:
i. AGC/Comfort Ti-AC40, or similar to meet code
ii. Sun Guard/SN-68, or similar to meet code
iii. PPG/Solarban 60, or similar to meet code
iv. Viracron/VE1-2M, or similar to meet code
4. Spandrel Glass (SG) 1/4" thick, Spandrel Ceramic Glass, (Color: Gray/black or as noted on drawings) by Old Castle Building Envelope (419) 666-2000, Contact: Doug Dewar
5. Frosted Window Film, 3M Dusted Crystal Translucent Window Film. Apply on the interior side of glazing.

- B. Glazing Materials:
1. Glazing Sealants: Provide elastomeric glazing sealants suitable for applications indicated; compatible with one another and with other materials they will contact, complying with ASTM C920.
2. Glazing Tape: Provide preformed, non-staining and non-migrating elastomeric tape, as recommended by tape and glass manufacturers for application indicated, complying with ASTM C 1281.
3. Glazing gaskets: Provide manufacturer's standard snap-on aluminum stops and neoprene, vinyl or EPDM glazing gaskets.
4. Provide setting blocks, spacers and edge blocks of material, size, and shape complying with referenced glazing standard, and compatible with surfaces contacted in installation.

- C. Fabrication: Factory fabricate and size all glass.

- 3.1 Installation

- A. Preparation:
1. Field verify measurements and conditions of installation.
2. Examine all details. Provide proper fitting to details indicated.
3. Glazing channel dimensions shown are intended to provide for necessary bite on glass, minimum edge clearance and adequate glazing materials thickness, with reasonable tolerances. Adjust as required by job conditions at time of installation.
B. Install glass and glazing in accordance with the GANA "Glazing Manual" and glass manufacturer's recommendations.
1. Install insulating glass units to comply with recommendations by Sealed Insulating Glass Manufacturers Association (SIGMA).
C. Install setting blocks of proper size at quarter points of sill rabbet. Provide spacers as required.
D. Install glazing sealants, tapes and gaskets in accordance with manufacturer's recommendations. Set glass without springing and install securely to prevent rattling or breakage.
E. Protect glass from breakage during remaining construction. Do not remove non-permanent labels until final acceptance.

DIVISION 9 – FINISHES

SECTION 09260 - GYPSUM BOARD SYSTEMS

- 1.1 General: Provide gypsum board systems as shown and specified.

- A. Standards: Materials and installation shall conform to the following:
1. GA 214-90 "Levels of Gypsum Board Finish."
2. GA-216 "Specifications for Application and Finishing of Gypsum Board."
3. USG "SA923 Drywall/Steel Framed Systems."

- 2.1 Materials:

- A. Manufacturer: United States Gypsum Co. (USG), (800) 874-4968, internet www.usg.com.
B. Metal framing: Comply with ASTM C 754 and ASTM C 645 for materials and sizes.
1. Partition metal framing:
a. Studs: Galvanized steel, C-shaped, sizes indicated, 20 gage "S720"
b. Runners: Match studs, type recommended by stud manufacturer for floor and ceiling support of studs. Provide flexible ceiling runners for full height metal stud framed partitions continuous from floor to underside of structural members or deck above.
C. Ceiling and Soffit metal framing/suspension systems:
1. Small areas: Metal stud framing of appropriate size and gage for spans indicated.
2. Large areas: Furring channel "Grillage" or "Direct Suspension System" designed for concealed support of gypsum board ceilings, of proper type for use indicated.
3. Furring members: 20 gage, galvanized steel screw type, hat-shaped furring.
D. Gypsum board panels: USG "Sheetrock" complying with ASTM C1396, tapered edge face panels, 48" wide, in maximum lengths available to minimize end joint conditions, 5/8" thick.
1. General use panels: Sheetrock Regular panels.
2. Fire rated panels: Sheetrock Firecode Core panels.
3. Water-resistant panels: Sheetrock HUMITEK panels.
E. Cement board: USG DUROCK Cement Board, 5/8" thick x manufacturer's standard width, complying with ANSI A118.9, and in maximum lengths available to minimize end-to-end butt joints.

- F. Fasteners: USG Type "S" bugle head screws for metal framing, USG Type "W" bugle head screws for wood framing, manufacturer's recommended length for panel thickness indicated.
G. Trim: Galvanized steel with knurled and perforated flanges. USG Dur-A-Bead corner bead, No. 2008 casing bead metal trim, No. 093 Control Joint.
H. Joint treatment: USG Joint Treatment System, utilizing "Sheetrock Brand Joint Tape", and "Sheetrock Brand Setting-Type (DURABOND)" compound for tape bedding and topping.
I. Adhesives: USG "Sheetrock Brand Setting-Type (DURABOND) 210 or 90" compound for tape bedding and topping.
J. Acoustical sealant: USG Sheetrock Acoustical Sealant, water-base type, gunnable sealant for sealing sound-rated gypsum board systems.
K. Sound attenuation insulation: USG Thermafiber unfaced 3-1/2" thick, mineral fiber insulating batts/blankets; standard lengths and widths required to coordinate with spaces insulated.

- 3.1 Installation

- A. Install metal wall and partition framing and ceiling suspension/ support systems in accordance with USG Bulletin SA 923 and complying with ASTM C754.
1. Ceiling suspension/ support systems: Metal furring system/direct suspension or steel stud framing system.
2. Wall and partition framing:
a. Install steel studs per schedule or at spacing indicated with bottom and top runner tracks anchored to substrates. Provide flexible ceiling runner tracks at full height partitions.
b. Terminate partition stud system 4" above ceilings, except where indicated to be extended to structural support or roof deck above. Brace tops of partition framing to structure or roof deck at maximum 4'-0" on center spacing.
c. Frame openings more than 2'-0" wide with two 20 gage studs at each jamb.
d. Coordinate the installation of supplementary blocking and nailers, provided under Section 06100 work, to support shelving, millwork, toilet accessories, and similar work that cannot be adequately supported by gypsum board alone.
B. Application and Finishing: Install and finish gypsum board to comply with ASTM C 840 and Gypsum Association GA 216 "Recommended Specifications for the Application and Finishing of Gypsum Board."
1. Screw fasten all gypsum board panels.
2. Metal Trim: Install metal corner beads at external corners of gypsum board work and metal trim wherever edge of gypsum board would be exposed. Use longest practical lengths.
3. Control Joints: Locate and install control joints in accordance with USG Bulletin SA923 "Good Design Practice" recommendations.

- C. Acoustical Treatment:
1. Where sound-attenuation insulation is indicated, seal gypsum board construction at perimeters, control joints, junction boxes, openings and penetrations with a continuous bead of acoustical sealant including a bead at both faces of partitions.
2. Install sound attenuation insulation at scheduled partitions and ceilings. Install insulation in single layer of required thickness. Extend full thickness over entire area to be insulated. Cut and fit tight around obstructions. Fill all voids.
3. At openings and cutouts, fill open spaces between edges of gypsum board and fixtures, cabinets, ducts, and other flush or penetrating items, with continuous bead of acoustical sealant.
4. Seal sides and backs of electrical boxes to completely close up openings and joints with a bead of acoustical treatment.

- D. Finishing:
1. Comply with manufacturer's instructions for mixing, handling, and application of materials. Apply treatment at joints both directions, at flanges of trim accessories, penetrations of gypsum board (electrical boxes, piping, and similar work), fastener heads, surface defects, and elsewhere as indicated. Apply in manner that will result in each of these items being concealed when applied decoration has been completed.
2. Apply joint tape at joints between gypsum boards, except where trim accessories are indicated.
3. Interior Exposed Gypsum Board Finish: Level 5 Finish.
a. Locations: Typical for all walls and ceilings, unless otherwise indicated
b. Finish interior gypsum board by applying the following joint compounds in four coats (not including prefill of openings in base), and sand between coats and after last coat:
c. Embedding and First Coat: Setting-type joint or taping compound.
d. Fill (Second) Coat: Setting-type topping compound.
e. Fill (Third) Coat: Setting-type topping compound.
f. Finish (Fourth) Coat: Skim coat entire surface.
4. Interior Concealed Gypsum Board: Level 3 Partial Finishing.
a. Finish concealed gypsum board construction that requires finishing same as exposed gypsum board construction, except the third coat and sanding can be omitted.

- E. Cement Board: Install cement board as a 16" high base at all kitchen and kitchen cook line wall types as indicated on drawings.

SECTION 092816 - GLASS-MAT FACED GYPSUM BACKING BOARDS

- 1.1 General: Provide Fiberglass-mat faced, moisture resistant gypsum backer board as shown and specified.

- A. Standards: Materials and installation shall conform to the following:
1. ASTM C840 Standard Specification for Application and Finishing of Gypsum Board.
2. ASTM C1002 Standard Specification for Steel Self Piercing Tapping Screws for the Application of Gypsum Panel Products or Metal Plaster Bases to Wood Studs or Steel Studs
3. ASTM C1178 Standard Specification for Glass Mat Water-Resistant Gypsum Backing Panel
4. ASTM D3273 Standard Test Method for Resistance to Growth of Mold on the Surface of Interior Coatings in an Environmental Chamber
5. ASTM D6329 Standard Guide for Developing Methodology for Evaluating the Ability of Indoor Materials to Support Microbial Growth Using Static Environmental Chambers.
6. ASTM E96 Standard Test Methods for Water Vapor Transmission of Materials
7. Tile Council of North America, Inc. (TCNA): TCA Handbook for Ceramic Tile Installation, Current Edition.

- 2.1 Materials:

- A. Manufacturer: Georgia-Pacific Gypsum LLC, (800) 225-6119, internet: www.buildgyp.com
B. Fiberglass-Mat Faced Gypsum Backing Board: DensShield Fireguard Tile Backing Board complying with ASTM C1178, Type X, Square edges, 4' wide in maximum lengths available to minimize end joint conditions, 5/8" thick. Surfacing: Coated fiberglass mat on face, back and long edges.
1. General use panels: 5/8" DensShield Fireguard Tile Backer, Georgia-Pacific Gypsum.
C. Fasteners: Screws meeting ASTM C1002, with corrosion resistant treatment. Size and type per manufacturer's recommendations:
1. Walls (Steel Frame): Bugle head, fine thread, sharp point rust resistant drywall screw
2. Walls (Walls Frame): Bugle head, coarse thread, sharp point rust resistant screw
D. Metal Framing, Trim, joint treatment, adhesives, acoustical sealant, and sound attenuation insulation: Refer to Section 09260 Gypsum Board Systems

- 3.1 Installation

- A. Install DenShield at all tile walls excluding hood area as indicated on drawings.
B. General: Install in accordance with ASTM C840, manufacturer's recommendations and TCA Handbook for Ceramic Tile Installation.
1. Manufacturers Recommendations: refer to Current "Product Catalog", Georgia Pacific Gypsum.
a. Attach DensShield Tile Backer with grey side facing the interior. Tile should be applied on the grey coated side of DensShield Tile Backer. Cut panel to required size and make cutouts. Fit ends and dges closely. Do not leave gaps between panels.
b. DensShield Tile Backer may be cut by using a utility knife to score, then snap, working from the grey face side.
c. For walls, when used as a tile substrate a minimum 20-gauge steel or wood framing should be spaced no greater than 24" o.c. for 5/8" DensShield Tile Backer. Board can be applied horizontally or vertically.
d. Fasteners shall be spaced 6" o.c. for walls for wood and steel framing. Do not countersink. Drive fasteners flush with grey coated surface. See manufacturer installation Fastener Guide for proper selection.
e. In all corners, imbed with a bead of flexible sealant when installing panels into corner. Apply self-adhesive 2" wide fiberglass mesh tape and bed tape on all joints and corners with material used to set tiles.
f. Caulk or seal fixture/plumbing penetrations and abutments to dissimilar materials.
g. Do not use all purpose joint compound or tape in wet areas.
h. Do not apply DensShield Tile Backer directly to concrete or masonry block. Framing or furring of the walls is necessary.
i. DensShield Tile Backer should not be used for exterior installations.
j. DensShield Tile Backer panels should not be used as a base for nailing and mechanical fastening.
k. DensShield Tile Backer has a built in moisture barrier. Never install vapor retarders directly behind DensShield Tile Backer panels. In retrofit applications, some paints or other wall coverings may constitute a vapor barrier; remove or effectively penetrate these coverings prior to installing DensShield Tile Backer panels.
C. Refer to Section 09260 Gypsum Board Systems for additional installation and sound treatment instructions

SECTION 09330 - QUARRY TILE

- 1.1 General: Provide quarry tile flooring and base as shown and specified.

- A. Standards: Materials and installation shall conform to the following:
1. ANSI A137.1 "Ceramic Tile."
2. TCA "Handbook for Ceramic Tile Installation."

- 2.1 Materials:

- A. Manufacturers:
1. Quarry Tile: Daltile, (877) 556-5728, internet: http://daltile.com
a. For ordering purposes, email all orders to chipotle@daltile.com
2. Waterproofing, Setting and Grouting Materials:
a. Setting and Grouting Materials and Tile Base Membrane: Mapei
i. For ordering purposes, email all orders to chipotle@daltile.com
ii. For technical questions, contact Mapei, (800) 992-6273, internet: www.mapei.com
B. Quarry Tile: Daltile 6" x 6" x 1/2" Quarry Textures with 5" base as scheduled on finish plan and appropriate trim; Color: "Ashen Gray" 0703
1. Entire Kitchen Area: Provide non-abrasive finish quarry tile.
2. Rest Rooms: Provide non-abrasive finish quarry tile.
3. Outside Corner Cove Base (Kitchen): HQC-(L or R)-3565 5" x 6"
4. Inside Corner Cove Base: #QB-3565 1" x 5"
5. Bullnose Coveless Base: #Q-1665, 6" x 6"
6. Bullnose Corner Coveless Base: #QCRL-1665, 6" x 6"
C. Waterproofing for elevated floor slabs: Mapei, Mapelastic AquaDefense, Premium Waterproofing and Crack Isolation Membrane
D. Setting Adhesive: Mapei, Ultraflex 3, Color: Gray
E. Grout: Mapei, Kerapoxy IEG CQ, Color: #9, "Gray", 1/4" grout joints.
F. Quarry Tile Base Membrane: Mapei, Mapelastic AquaDefense, Premium Waterproofing and Crack Isolation Membrane

- 3.1 Installation

- A. Preparation: Clean substrate surfaces, scheduled to receive quarry tile, thoroughly and remove all coatings that may impair bond.
1. Center tile fields both directions in each floor area. Adjust layout to minimize tile cutting. Avoid tile less than one-half size. Locate cuts to be least conspicuous.
2. Maintain units uniformly "in plane." Provide straight, uniform joint widths and grout lines.
B. Elevated Floor Slabs: Install waterproofing membrane at elevated floor slab surfaces scheduled to receive quarry tile floor finish. Install membrane materials in accordance with manufacturer's installation instructions to produce a waterproof membrane of uniform minimum 30 mil thickness bonded securely to substrate.
1. Extend waterproofing up vertical wall surfaces minimum 10" high.
2. Extend membrane down into floor drain flanges to assure continuous waterproofing at drainage points.
C. Wet Areas: Install waterproofing membrane at all quarry tile wall base. Install membrane materials in accordance with manufacturer's installation instructions to produce a waterproof membrane of uniform minimum 30 mil thickness bonded securely to substrate.
1. Extend waterproofing up all vertical wall surfaces receiving quarry tile base minimum 10" high. Extend waterproofing membrane 10" minimum horizontally from all vertical wall surfaces receiving quarry tile base.
D. Installation: Install, grout and clean ceramic tile in accordance with referenced TCA installation details and ANSI standard specifications for setting methods scheduled.
1. Floors: Latex-portland cement mortar on concrete; TCA detail F113 and ANSI A108.5, grout ANSI A108.10.
2. Base: Latex-portland cement mortar on cement board.

SECTION 09340 - CERAMIC TILE

- 1.1 General: Provide ceramic wall tile as shown and specified.

- A. Standards: Materials and installation shall conform to the following:
1. ANSI A137.1 "Ceramic Tile."
2. TCA "Handbook for Ceramic Tile Installation."

- 2.1 Materials:

- A. Manufacturers:
1. Ceramic Tile and Accent Tile: Daltile, P: (877) 556-5728, internet: http://daltile.com
a. For ordering purposes, email all orders to chipotle@daltile.com
B. Ceramic Tile: Series - Color Wheel Glazed Ceramic:
1. Kitchen Tile or as noted in plans
a. Color - White FL90, Semi-Gloss, Size - 4 x 16, Pattern - Stacked Bond
2. Accent Tile, Series - Color Wheel Glazed Ceramic
a. Color - Chipotle Brick Metallic 1.0 #9999710686, Size - 3 x 12, Pattern - Stacked Bond
b. Alternate Accent Tile only when approved by Arch PM and Chipotle DM
i. Series - Remedy, Color - Alchemy RD25, Size - 2 x 9, Pattern - Stacked Bond
ii. Series - Marrazzi, Color - Artesen AT25, Size - 2 x 4, Pattern - Brickjoint Mosaic
C. Setting Adhesive: Thinsit Mortar, Mapei, Ultraflex LFT - Gray

- D. Grout:
1. Kitchen Tile or as noted in plans
a. Mapei, Series - Flexcolor CQ - Gray #09, 1/8" grout joints.
2. Accent Tile
a. Mapei, Series - Flexcolor CQ - Chocolate #07, 1/8" grout joints.

- 3.1 Installation

- A. Preparation: Clean substrate surfaces scheduled to receive ceramic tile thoroughly and remove all coatings that may impair bond.
1. Protect surrounding work from damage.
2. Remove any curing compounds or other contaminants.
3. Vacuum clean surfaces and damp clean.
4. Install cementitious backer board or glass-mat faced gypsum backing board as indicated in drawings in accordance with ANSI A108.11 and board manufacturer's instructions. Tape joints and corners, cover with skim coat of dry-set mortar to a feather edge.
5. Prepare substrate surfaces for adhesive installation in accordance with adhesive manufacturer's instructions.
B. Kitchen:
1. Install, grout and clean ceramic tile in accordance with referenced TCA installation details and ANSI standard specifications for setting methods scheduled.
2. Lay tile in horizontal stack bond, following detail drawings for layout considerations. Horizontal rows of tile shall be full-height courses, unless noted otherwise.
3. Arrange pattern so that a full tile or joint is centered on each wall horizontally and that no tile less than 1/2 width is used at the ends of the wall. Exception: when one end of the wall is a tile-to-gypsum board transition. Do not interrupt tile pattern through openings.
4. Use specified stainless steel corner guards at tile-to-tile and tile-to-FRP outside corners.
5. Use corner bead of 100% silicone sealant, color to match grout, at inside corners where tile meets tile.
6. Use corner bead of 100% silicone sealant, white, at inside corners where tile meets paint gyp. board, tile meets FRP or tile meets aluminum.
7. Cut and fit tile to penetrations through tile, leaving sealant joint space. Place tile joints uniform in width, subject to variance in tolerance allowed in the size. Make joints watertight, without voids, cracks, excess mortar, or excess grout.
8. Sound tile after setting. Replace hollow sounding units.
9. Keep expansion joints free of adhesive or grout. Allow tile to set for a minimum of 48 hours prior to grouting. Apply sealant to junction of tile and dissimilar materials and junction of dissimilar planes. Refer to section 07900 Joint Sealers.
10. Clean tile and grout surfaces.

Consultant:

R/A

Red Architecture

589 W. NATIONWIDE BLVD. SUITE B
COLUMBUS, OHIO 43215 (614) 487-8770

FOR
CONSTRUCTION

COPYRIGHT 2023
THIS DRAWING IS AN INSTRUMENT OF SERVICE
AND AS SUCH REMAINS THE PROPERTY OF
CHIPOTLE MEXICAN GRILL, INC.. PERMISSION FOR
USE OF THIS DOCUMENT IS LIMITED AND CAN BE
EXTENDED ONLY BY WRITTEN AGREEMENT WITH
CHIPOTLE MEXICAN GRILL, INC..



CHIPOTLE MEXICAN GRILL, INC.
PO BOX 182566
COLUMBUS, OH 43218-2566
TELEPHONE: 614.318.2400
INTERNET: WWW.CHIPOTLE.COM

STORE NO.: 4870
WALNUT HILLS
1202 E MCMILLAN STREET
CINCINNATI, OH 45206

Issue Record:

11/03/23 PERMIT SET
05/08/24 CONSTRUCTION SET

Revisions:

Drawn: JTH, PH
Checked: TC

Project No.

CMG1144

Contents:

ARCHITECTURAL
SPECIFICATIONS

G015

SECTION 09510 - SUSPENDED CEILING SYSTEMS

1.1 General: Provide acoustical ceiling systems as shown and specified.

- A. Standards: Materials and installation shall conform to the following:
1. CISA "Acoustical Ceilings - Use and Practice."
 2. ASTM C635.
 3. ASTM C636.
- B. Related Sections:
1. 09515 Cementitious Wood Fiber Acoustical Panels: Suspension system.

2.1 Materials:

- A. Manufacturer:
1. USG Interiors, Inc., (800) 950-3839, www.usg.com
 2. Pittcon Industries, (800) 637-7638, www.pittconindustries.com
- B. Ceiling Panels: USG "Sheetrock Lay-In ClimaPlus No. 3270" ceiling panels with white, stipple texture, vinyl facing, 24" x 48" x 1/2".
- C. Light Pocket: Pittcon "LP-700-800", White, Height of cove should be field verified by GC to end on a full tile height.
1. Light pocket can have up to 6 week lead time and should be ordered as soon as possible.
 2. Light pocket endcap should only be installed when the end of the cove is not against a wall.
- D. Suspension System: Provide intermediate duty, structural class, direct hung systems adequate to support light fixtures, ceiling diffusers and other normal accessories.
1. Exposed "Tee" Grid System for use with Lay-In Ceiling panels: USG "Donn DX System" non-fire rated with 15/16" exposed face, cold-rolled galvanized steel with aluminum face cap, white paint finish on exposed surfaces. Provide hemmed edge aluminum wall angles, 15/16" exposed leg, white paint finish matching exposed grid.
 2. Concealed "Tee" Grid System for use with Painted Gypsum Board Ceilings & Soffits or with Cementitious Wood Fiber Acoustical Panels (Tectum): USG "DGLW" Heavy Duty Drywall Suspension System with 1 5/8" deep by 1 1/2" wide main tees and 1 1/2" deep by 1 1/2" wide cross tees.
 3. Hanger Wire: No. 12 SWG galvanized steel wire.
 4. Heavy Duty "Tee" Grid System for use with Felt Baffle Ceiling System: USG Donn Brand DX/DXL with 15/16" wide face tees, color: black

3.1 Installation

- A. Install acoustical ceiling materials and suspension systems in strict accordance with manufacturer's recommendations, complying with governing regulations and industry standards applicable to the work.
- B. Suspension system installation shall be laser leveled with a maximum surface leveling tolerance of 1/8" in 12'-0".
- C. Install exposed Tee suspension systems with main tees nominally 12 ft long spaced 48 in O.C. and cross tees nominally 4 feet long spaced 24 in O.C.
- D. Install concealed Tee suspension systems with main tees nominally 12 ft long spaced 24 inches O.C. and cross tees nominally 2 ft long spaced 48 in O.C.
- E. Hanger wire shall be spaced 48" O.C. along main tees, at all four corners of light fixtures (where applicable), at midpoint of cross tees adjacent to light fixtures and duct outlets, and adjacent to main tee splices.
- F. Secure wire hangers by looping and wire-tying either directly to building structure or to hangers that are secure and appropriate for substrate.
- G. Provide edge trim molding at perimeter of acoustical ceiling installation and intermediate vertical surfaces. Use maximum lengths. Miter trim corners to Provide tight, accurate joints. Connect moldings securely to substrate surfaces.

SECTION 09653 - RUBBER WALL BASE

1.1 General: Provide resilient rubber wall base as shown and specified.

- A. Standards: Materials and installation shall conform to the following:
1. ASTM D 2240 Rubber - 85 Shore A

2.1 Materials:

- A. Manufacturer: Johnsonite, Inc., (800) 899-8916, internet: www.johnsonite.com
1. Basis-of-Design Product Rubber Wall Base:
 - a. Resilient Rubber:
 1. .125" (3.17 mm) Thickness
 2. "Black" color
 3. Straight (toeless) or coved as specified on finish plan
 4. Inside and outside corners with 4" returns.
- B. Alternate Wall Base only when approved by Arch PM and Chipotle DM.
1. Vinyl Wall Base
 - a. .125" (3.17 mm) Thickness
 - b. "Black" color
 - c. Straight (toeless) or coved as specified on finish plan
 - d. Inside and outside corners with 4" returns.
- C. Setting Adhesive
1. For porous surface applications: Johnsonite 960 Acrylic Cove Base Adhesive
 2. For non-porous surface applications: Johnsonite 946 Contact Bond Adhesive or polymer based alternative

3.1 Installation:

- A. Preparation: Clean substrate surfaces scheduled to receive resilient rubber and vinyl wall base thoroughly and remove all coatings that may impair bond. A uniform temperature of at least 65 degrees Fahrenheit shall be maintained for 24 hours before, during and after the installation is completed. The wall base and adhesives shall be conditioned in the same manner. Colled wall base shall be uncoiled and lay flat for at least 24 hours at 65 degrees Fahrenheit prior to installation. Floor and walls shall be clean, dry, and free of dust, all paints, wallpaper, and all other foreign material, which may affect proper adhesive bonding. Wall base may be installed on interior plaster, gypsum wall board, concrete, masonry, mineral-reinforced cement board or similar porous surfaces. Wall base shall not be installed on surfaces that will be exposed to drastic temperature changes or moisture.
- B. Application: Use a 1/8" square notch trowel to apply adhesive. Allow adhesive to set up and then apply wall base in accordance with manufacturer's instructions.

SECTION 09770 - SPECIAL WALL SURFACING - PHENOLIC INTERIOR WALL PANELS

1.1 General: Provide Stonewood solid phenolic panels and accessories for interior walls and millwork as shown and specified.

1.2 Related Sections:

- A. Section 05400 - Cold Formed Metal Framing
- B. Section 06210 - Finish Carpentry and Millwork
- C. Section 07900 - Joint Sealers
- D. Section 09260 - Gypsum Board Systems

1.3 Standards: Materials and construction shall conform to the following:

- A. ASTM D638 - 10 Standard Test Method for Tensile Properties of Plastics.
- B. ASTM D790 - 10 Standard Test Methods for Flexural Properties of Unreinforced and Reinforced Plastics and Electrical Insulating Materials.
- C. ASTM E84 - 12 Standard Test Method for Surface Burning Characteristics of Building Materials.
- D. NEMA Standards Publication LD3-2005. High pressure decorative laminates.

1.4 Design/Performance Requirements:

- A. Design and size of wall panel assemblies including wall panels, mounting system to support weight of panels.
- B. Allow for thermal movements from ambient and surface temperature changes by preventing buckling, opening of joints, overstressing of components, failure of joint sealants, failure of connections, and other detrimental effects. Base calculations on expected movement of material as defined in fabrication guidelines.

1.5 Quality Assurance:

- A. Manufacturer's Qualifications:
1. Sufficient plant facilities to provide quality and quantity of materials as required without delaying progress of work.
 2. Minimum of 40 years of experience in paper saturation of phenolic resin, and producing phenolic paper laminate.
- B. Fabricator:
1. Fabricated by the manufacturer, and/or;
 2. Contracted by the customer, minimum 5 years' experience in fabrication work for the size and complexity of the projects.
- C. Installer
1. Proven professional installer with a minimum of 5 years of documented experience.
 2. Approved by the manufacturer.

1.6 Delivery, Storage and Handling:

- A. Refer to Section 01400 Quality Requirements.
- B. Delivery: Deliver materials in manufacturer's original unopened containers/packages, with labels clearly identifying product name, manufacturer, color/texture and weight.
- C. Storage:
1. Keep panels dry and stored indoors in original packaging until installation.
 2. Store Stonewood panels on a smooth, dry, flat surface, making sure there are no bends or bowing in the load.
 3. Do not store directly on cold concrete floors as moisture may migrate.
 4. Do not store under heating units or air conditioning units.
 5. Keep load stored within outer wrap until use. Remove pallet straps once load is moved to storage area.
 6. Reseal plastic wrap if partial load is used.
 7. Keep foam dividers in place.
- D. Handling:
1. Handle materials in accordance with manufacturer's instructions.
 2. Protect materials during handling to prevent damage.
 3. When moving sheets, lift evenly to avoid dragging panels across each other and scratching the surface. PLEASE TAKE CARE NOT TO SCRATCH THE SURFACE OF THE PANEL DURING HANDLING, MACHINING AND INSTALLATION.

1.7 Warranty:

- A. Limited Warranty: Fibbers warrants Stonewood for a period of 10 years. Refer to www.stonewoodpanels.com for details.

1.8 Project Conditions:

- A. Environmental Limitations: Buildings are to be fully enclosed prior to installation with sufficient heat (70 degrees) and ventilation consistent with good working conditons for finish work.
- B. Maintain environmental conditions (temperature, humidity, and ventilation) within limits recommended by manufacturer for optimum results. Do not install products under environmental conditions outside manufacturer's absolute limits.
- C. Field Measurements: Verify locations of structural members and wall opening dimensions by field measurements before composite wall panel fabrication and indicate field measurements on Shop Drawings.

2.1 Manufacturer:

- A. Fibersin Industries, Inc. PO Box 808, Oconomowoc, WI 53066. Phone: (262) 567-4427, Fax: (262) 567-4814, Web Site: www.stonewoodpanels.com Email: info@fibersin.com
- B. Made in the United States from materials sourced in the USA.

2.2 Application:

- A. Apply Solid Phenolic Laminate Wall Panels at walls and other surfaces as indicated on the Drawings. Phenolic Wall Panels are architectural wall panels applied over a sheathed stud wall or other solid blocking per Drawings.

2.3 Interior Stonewood:

- A. Material: Solid phenolic laminate panel w/o overlay.
- B. Color: Black ND
- C. Finish: Matte
- D. Standard Size: 48"x96", fabricator to trim height to 47"
- E. Panel Thickness: 5/16", 1/2"
- F. Panel Core: HR Black

2.4 Minimum Material Properties

A. NEMA Requirements:	<u>NEMA Requirements</u>	
	3.11	
Dimensional Change:	0.3% Maximum	0.25%
Length (Machine Direction)	0.7% Maximum	0.50%
Width (Cross Direction)		
Density (PCF)	82	

B. Mechanical Properties:	<u>NEMA Requirements</u>	
	Property	
Flexural Strength ASTM		
D-790		
MD (psi)	18,000	20,000
CD (psi)	12,000	16,000
Flexural Modulus ASTM		
D-790		
MD (psi)	1.6x10 ⁶	2.0 x10 ⁶
CD (psi)	1.4x10 ⁶	1.5x10 ⁶
Tensile Modulus ASTM		
D-638		
MD (psi)	18,000	18,000
CD (psi)	12,000	13,000

C. Fire Resistance:	<u>Class A (0.250")</u>		<u>Class B (0.250")</u>
	Flame Spread Index - ASTM E-84 (BLDG):	5	30
	Smoke Developed Values - ASTM E-84 (BLDG):	5	105
	Fire Rating (Standard Product is Class B):	A	B

D. Manufacturing Tolerance:	<u>NEMA Requirements</u>	
	Property	
Thickness (.156 to .375)	+/- .020	
Thickness (above .375 to 1.000)	+/- .030	
CNC Shaped Size (Length - Width)	+/- .020	
Drill Diameter	+/- .003	
Drill Depth	+/- .020	
CNC Hole to Hole	+/- .020	
CNC Hole to Edge (1 Oper)	+/- .020	
CNC Hole to Edge (2 Oper)	+/- .030	
Routing - (Slots Width and Length)	+/- .015	
Routing - (Slots Depth)	+/- .020	

2.5 Accessories (Fasteners):

- A. Panel Fasteners: #10 x 1-1/4" flat phillips head black oxide wood screws to be used with wood blocking and #10 x 1-1/4" flat phillips head black oxide sheet metal screws to be used with sheet metal blocking as recommended by the manufacturer.
- B. Provide exposed fasteners with heads matching color of composite wall panels by means of factory-applied coating.
- C. Fasteners shall by designed to withstand effects of dead load and accommodate hydrothermal expansion/contraction of panel.
- D. Wall Panel Accessories: Provide components required for a complete composite wall panel assembly including trim, flashings, sealants, gaskets, fillers, closure strips, and similar items. Match material and finish of composite wall panels unless otherwise indicated.

3.1 Manufacturer's Execution Instructions:

- A. Compliance: Comply with manufacturer's/fabricator's/supplier's product data, handling and installation instruction/manual, shop drawings, shipping container/package ticket identification, etc.

3.2 Examination:

- A. Verify correct panels received including dimension, tolerance, color/texture.
- B. Verify correct attachment system received for the specific project/job.
- C. Verify all the documents including shop drawing and installation guidelines.
- D. Verify installation conditions are satisfactory to receive work of this section before the commencement
- E. Verify substrate installation is complete, flat, and true to plane.
- F. If substrate preparation is the responsibility of another installer, notify Architect of unsatisfactory preparation before proceeding.

3.3 Preparation:

- A. Field Measurements: Verify prior to fabrication and installation of the cladding panel.
- B. Protect surrounding areas and surfaces to preclude damage during work of this section.
- C. Lay out work before beginning installation as necessary for true, plumb and aligned panel installations.
- D. Verify locations of joints and panel lengths.

3.4 Installation:

- A. Conform to manufacturer's instructions and provisions of shop drawings.
- B. Install to allow hydro-thermal expansion/contraction.
- C. Use appropriate techniques/tools to work with the panel.
- D. Do not force to fit, do not bend, stretch/compress.
- E. Make cutting and fitting neat, square, and true. Where required cut, de-burr edges, and clean filings from adjacent surfaces.
- F. Do not install damaged or questionable panels.
- G. Install solid phenolic wall panels plumb and level and accurately spaced.
- H. Anchor panels and other components of the work securely in place, with provisions for thermal and structural movement.
- I. Shim or otherwise plumb substrates receiving composite wall panels.
- J. Do not use construction adhesives to apply wall panels directly to substrates or wall board. Use mechanical fasteners only.

3.5 Erection Tolerances:

- A. Shim and align composite wall panel units within installed tolerance of 1/4 inch in 20 feet, non-accumulative, on level, plumb, and location lines as indicated and within 1/8 inch offset of adjoining faces and of alignment of matching profiles.

3.6 Field Quality Control:

- A. Manufacturer's Field Service: Provide field services to ensure product installation is in accordance with manufacturer's/fabricator's/supplier's instructions and installation manual, shop drawings etc.

3.7 Adjusting:

- A. Correct identified defects and irregularities.
- B. Replace damaged soiled, and discolored work.

3.8 Cleaning:

- A. Leave installation clean and free from residue and debris from work of this Section.
- B. Panels best cleaned with warm soapy water and rinsed with clear water; allowed to dry fully.

SECTION 09900 - PAINTS AND COATINGS

1.1 General: Provide paints and coatings as shown and specified.

- A. Provide surface preparation, prime, intermediate and finish coatings for interior and exterior and existing scheduled surfaces and items.
- B. Provide Tenant-selected finishes and colors for all exposed surfaces, unless otherwise indicated.

1.2 Related Documents:

- A. Drawings and general provisions of the Contract, including General and Supplementary Conditions and Division 1 Specification Sections, apply to this section.

1.3 Summary:

- A. This section includes surface preparation and field painting of the following:
1. Exposed exterior items and surfaces.
 2. Exposed interior items and surfaces.
 3. Surface preparation, priming, and finish coats specified in this Section are in addition to shop priming and surface treatment specified in other Sections.

1.4 Quality Assurance:

- A. Applicator Qualifications: Engage an experienced applicator that has completed painting system applications similar in material and extent to that indicated for this Project with a record of successful in-service performance.
- B. Source Limitations: Obtain block fillers, primers and undercoat materials for each coating system from the same manufacturer as the finish coats.
- C. Provide lead free prime and finish coatings. All top coatings shall be mold and mildew resistant.

1.5 Delivery, Storage and Handling:

- A. Deliver materials to the Project Site in manufacturer's original, unopened packages and containers bearing manufacturer's name and label, and the following information:
1. Product name or title of material.
 2. Product description (generic classification or binder type).
 3. Manufacturer's stock number and date of manufacture.
 4. Contents by volume, for pigment and vehicle constituents.
 5. Thinning instructions.
 6. Application instructions.
 7. Color name and number.
 8. VOC content
- B. Store materials not in use in tightly covered containers in a well-ventilated area at a minimum ambient temperature of 45 degrees F (7 degrees C). Maintain containers used in storage in a clean condition, free of foreign materials and residue.
1. Protect from freezing. Keep storage area neat and orderly. Remove oily rags and waste daily. Take necessary measures to ensure that workers and work areas are protected from fire and health hazards resulting from handling, mixing and application.

1.6 Project Conditions

- A. Apply water-based paints only when the temperatures of surfaces to be painted and surrounding air temperatures are between 50 and 90 degrees F (10 and 32 degrees C) unless otherwise stated on the technical data bulletin.
- B. Apply solvent-thinned paints only when the temperature of surfaces to be painted and surrounding air temperatures are between 45 and 95 degrees F (7.2 and 35 degrees C).
- C. Do not apply paint in snow, rain, fog, or mist, or when the relative humidity exceeds 85 percent, or at temperatures less than 5 degrees F (3 degrees C) above the dew point, or to damp or wet surfaces.
1. Painting may continue during inclement weather if surfaces and areas to be painted are enclosed and heated within temperature limits specified by manufacturer during application and drying periods.

2.1 Manufacturers:

- A. Products: Subject to compliance with requirements, provide one of the products in the paint schedules.
- B. Manufacturers Names: The following manufacturer is referred to in the paint schedule by use of shortened versions of the name, which is shown below:
1. PPG Industries, Inc.
 2. Materials - No substitutions allowed.

2.2 Paint Materials, General

- A. Material Compatibility: Provide block fillers, primers, undercoats, and finish-coat materials that are compatible with one another and the substrates indicated under conditions of service and application, as demonstrated by manufacturer based on testing and field experience.
- B. Material Quality: Provide manufacturer's best-quality "professional" paint material of the various coating types specified. Paint-material containers not displaying manufacturer's product identification will not be acceptable.

Colors: Color guided selected by owner and will be strictly adhered too, unless otherwise noted.

C. Exterior Coatings:

Exterior Ferrous Metals:

Preparation: Remove all visible oil, grease, soil, rust and all other soluble contaminates from steel surface. Uniformly roughen surface with 150-grit paper. Remove all dust before solvent cleaning by the use of stiff bristle brush.

Prime: (1) coat PPG; 4020PF Series Pitt-Tech Plus Int/Ext DTM Acrylic Industrial Primer (90 g/L VOC): Applied at a dry film thickness of not less than 2.0 to 4.0 mils.

Finish: (2) coats PPG; 4216 Plus HP Series Pitt-Tech Plus Semi-Gloss DTM Industrial Enamels (90 g/L VOC): Applied at a dry film thickness of not less than 2.0 to 4.0 mils.

Application: Conventional or HVLP (high volume low pressure)

Exterior and Interior Gas Piping:

Preparation: Remove all visible oil, grease, soil, rust and all other soluble contaminates from pipe surface. Remove all dust before solvent cleaning by the use of stiff bristle brush.

Prime: (1) Coat PPG; 4020PF Series Pitt-Tech Plus Int/Ext DTM Acrylic Industrial Primer (90 g/L VOC): Applied at a dry film thickness of not less than 2.0 to 4.0 mils.

Finish: (2) Coats PPG; 4216 Plus HP Series Pitt-Tech Plus Semi-Gloss DTM Industrial Enamels (90 g/L VOC): Applied at a dry film thickness of not less than 2.0 to 4.0 mils

Application: Conventional or HVLP (high volume low pressure)

Exterior Patio Railing:

Preparation: Remove all visible oil, grease, soil, loose paint, rust and all other soluble contaminates from steel surface. Remove all dust before solvent cleaning SSPC-SP1 by the use of stiff bristle brush. SSPC-SP3 may be required as a more aggressive preparation to remove loose mill scale, loose rust, loose paint and other loose detrimental foreign matter from the surface. Performance is better with more aggressive preparation.

Prime: (1) coat PPG; 95-3300 Durathane DTM Urethane Mastic (250 g/L VOC): Applied at a dry film thickness of not less than 3.0 to 5.0 mils.

Finish: (1) coat PPG; 95-3300 Durathane DTM Urethane Mastic (250 g/L VOC): Applied at a dry film thickness of not less than 3.0 to 5.0 mils.

Application: Conventional or HVLP (high volume low pressure) be done with conventional spray or airless equipment or brush or roller.

Exterior Prefinished Metal Wall Panels:

Preparation: Before applying primer or other surface treatments, clean galvanized metal surface to SSPC-SP1 that could impair bond of the various coatings. Remove oil, grease and soap film before priming use of Krud Kutter Metal Clean & Etch may be required on bare or new galvanized. Surface must be clean, dry and free of contaminants, including salt deposits. Additional prep may be needed to SSPC-SP2. Schedule cleaning and painting so dust and other contaminants from the cleaning process will not fall on wet, newly painted surfaces.

Note: Some selected areas of bare concrete surfaces will require (1) coat of Perma Crete 4-603XI Alkali Resistant Concrete Primer before steel installation over all concrete surfaces.

Owner Option 1:

Prime: (1) coat XIM Primer Bond - Applied at a dry film thickness of not less than 1.5 to 2.0 mils.

Finish: (2) coats PPG; 90-1110 Series Pitt-Tech Satint DTM Industrial Enamels (90 g/L VOC): Applied at a dry film thickness of not less than 2.0 to 4.0 mils.

Owner Option 2:

Prime: (1) coat PPG; 97-245 Pitt-Guard DTR Epoxy Mastic Primer (263 g/L VOC): Applied at a dry film thickness of not less than 4.0 to 7.0 mils.

Finish: (2) coats PPG; 95-3300 Durathane Urethane Mastic (240 g/L VOC): Applied at a dry film thickness of not less than 2.0 to 4.0 mils.

Owner Option 3 (Low VOC):

Prime: (1) coat PPG; Amerlock 2 Fast Dry VOC Compliant Epoxy (84 g/L VOC): Applied at a dry film thickness of not less than 4.0 to 6.0 mils.

Finish: (2) coats PPG; Amershiel VOC Aliphatic Urethane (84 g/L VOC): Applied at a dry film thickness of not less than 5.0 to 8.0 mils.

Application: Conventional or HVLP (high volume low pressure) be done with conventional spray or airless equipment or brush or roller.

Exterior Galvanized Metal:

Preparation: Before applying primer or other surface treatments, clean galvanized metal surface to SSPC-SP1 that could impair bond of the various coatings. Remove oil, grease and soap film before priming use of Krud Kutter Metal Clean & Etch may be required on bare or new galvanized. Surface must be clean, dry and free of contaminants, including salt deposits. Additional prep may be needed to SSPC-SP2. Schedule cleaning and painting so dust and other contaminants from the cleaning process will not fall on wet, newly painted surfaces.

Note: Some selected areas of bare concrete surfaces will require (1) coat of Perma Crete 4-503 Concrete Primer before steel installation over all concrete surfaces.

Owner Option 1:

Prime: (1) coat PPG; 6-209 SpeedHie Galvanized Metal Primer (400 g/L VOC): Applied at a dry film thickness of not less than 3.0 to 5.0 mils.

Finish: (2) coats PPG; 4216 Plus HP Series Pitt-Tech Plus Semi-Gloss DTM Industrial Enamels (90 g/L VOC): Applied at a dry film thickness of not less than 2.0 to 4.0 mils.

Owner Option 2:

Prime: (1) coat PPG; 97-245 Pitt-Guard DTR Epoxy Mastic Primer (263 g/L VOC): Applied at a dry film thickness of not less than 4.0 to 7.0 mils.

Finish: (2) coats PPG; 95-3300 Durathane Urethane Mastic (240 g/L VOC): Applied at a dry film thickness of not less than 2.0 to 4.0 mils.

Owner Option 3 (Low VOC):

Prime: (1) coat PPG; Amerlock 2 Fast Dry VOC Compliant Epoxy (84 g/L VOC): Applied at a dry film thickness of not less than 4.0 to 6.0 mils.

Finish: (2) coats PPG; Amershiel VOC Aliphatic Urethane (84 g/L VOC): Applied at a dry film thickness of not less than 5.0 to 8.0 mils.

Application: Conventional or HVLP (high volume low pressure) be done with conventional spray or airless equipment or brush or roller.

Consultant:

R/A

Red Architecture

589 W. NATIONWIDE BLVD. SUITE B
COLUMBUS, OHIO 43215 (614) 487-8770

FOR
CONSTRUCTION

COPYRIGHT 2023
THIS DRAWING IS AN INSTRUMENT OF SERVICE
AND AS SUCH REMAINS THE PROPERTY OF
CHIPOTLE MEXICAN GRILL, INC.. PERMISSION FOR
USE OF THIS DOCUMENT IS LIMITED AND CAN BE
EXTENDED ONLY BY WRITTEN AGREEMENT WITH
CHIPOTLE MEXICAN GRILL, INC..



CHIPOTLE MEXICAN GRILL, INC.
PO BOX 182566
COLUMBUS, OH 43218-2566
TELEPHONE: 614.318.2400
INTERNET: WWW.CHIPOTLE.COM

STORE NO.: 4870
WALNUT HILLS
1202 E MCMILLAN STREET
CINCINNATI, OH 45206

Issue Record:

11/03/23 PERMIT SET
05/08/24 CONSTRUCTION SET

Revisions:

Drawn: JTH,
PH Checked: TC

Project No.

CMG1144

Contents:

ARCHITECTURAL
SPECIFICATIONS

G016

GENERAL NOTES

1. STENCILS FOR PARKING MARKINGS AVAILABLE FROM PAVEMENT STENCIL COMPANY, PHONE: (800) 250-5547, EMAIL: STENCILS@PAVEMENTSTENCIL.COM
2. ALL SITE WORK INCLUDING PAVING, CURBING, PARKING, PARKING LOT LIGHTING, SIDEWALKS, LANDSCAPING AND DUMPSTER ENCLOSURE ARE EXISTING U.N.O.

Consultant:

R/A

Red/Architecture

589 W. NATIONWIDE BLVD. SUITE B
COLUMBUS, OHIO 43215 (614) 487-8770

FOR
CONSTRUCTION

COPYRIGHT 2023
THIS DRAWING IS AN INSTRUMENT OF SERVICE
AND AS SUCH REMAINS THE PROPERTY OF
CHIPOTLE MEXICAN GRILL, INC.. PERMISSION FOR
USE OF THIS DOCUMENT IS LIMITED AND CAN BE
EXTENDED ONLY BY WRITTEN AGREEMENT WITH
CHIPOTLE MEXICAN GRILL, INC..



CHIPOTLE MEXICAN GRILL, INC.
PO BOX 182566
COLUMBUS, OH 43218-2566
TELEPHONE: 614.318.2400
INTERNET: WWW.CHIPOTLE.COM

STORE NO.: 4870
WALNUT HILLS
1202 E MCMILLAN STREET
CINCINNATI, OH 45206

Issue Record:

11/03/23	PERMIT SET
05/08/24	CONSTRUCTION SET

Revisions:

Drawn:	Checked:
JTH, PH	TC

Project No.

CMG1144

Contents:

ARCHITECTURAL SITE
PLAN

SP100



EXISTING (1) 1" CONDUIT
FOR CLEARANCE BAR,
REFER TO ELECTRICAL
DRAWINGS

EXISTING (1) 1" CONDUIT
FOR CLEARANCE BAR,
REFER TO ELECTRICAL
DRAWINGS

NOTE: ALL CONDUIT TO BE
CENTERED BELOW FUTURE
SIGNAGE AND POSTS BY
TENANT SIGN VENDOR

EXISTING 6" BOLLARD

EXISTING (1) 1" CONDUIT
FOR LOOP DETECTOR,
CENTER ON PICK-UP
WINDOW, REFER TO
ELECTRICAL DRAWINGS

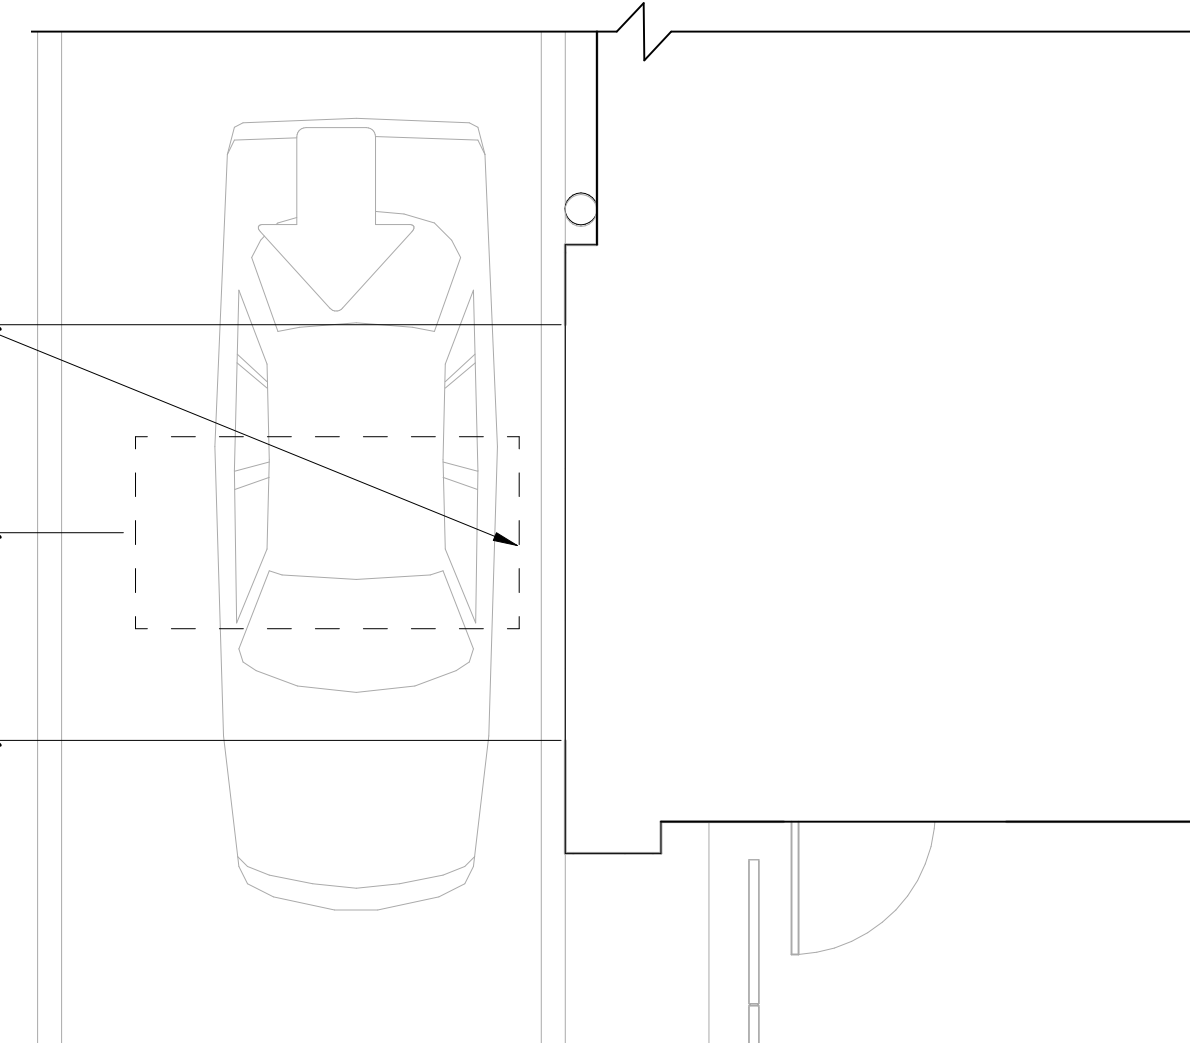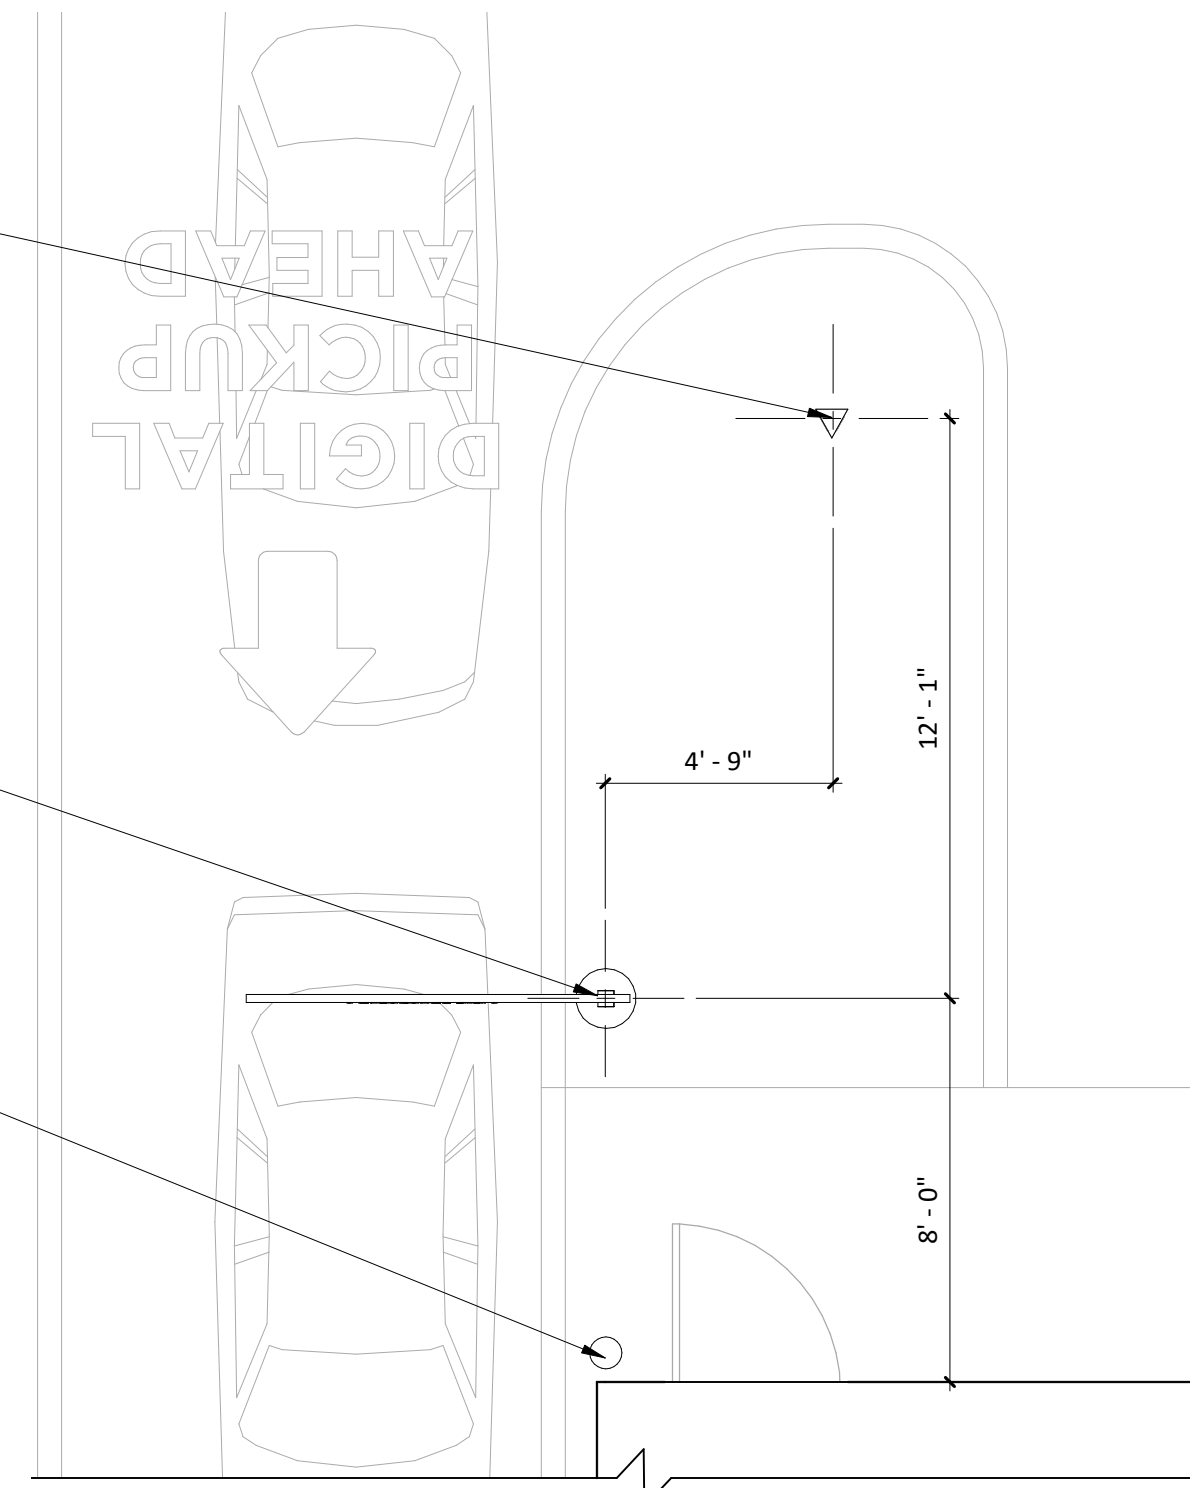

ARCHITECTURAL SITE PLAN DIMENSIONED
1/4" = 1'-0"

ACCESS TO
ADIACENT LOT

LOCATION OF HOTBOX
CONTAINING EXISTING
BACKFLOW PREVENTER
AND WATER METER

ANNOUNCE SIGN AND
FOUNDATION BY TSV,
EXISTING 1" CONDUIT; SEE
2/SP100

EXISTING EXCLUSIVE
1500 GALLON GREASE
INTERCEPTOR

CLEARANCE BAR AND
FOUNDATION BY TSV,
EXISTING 1" CONDUIT;
SEE 2/SP100

EXISTING 6" BOLLARD, TYP.

VICTORY PKWY

EXISTING CONCRETE
TO EXTEND 12 LF MIN
BEYOND CENTERLINE
OF WINDOW

EXISTING 6" BOLLARD, TYP.

EXISTING PICK-UP
WINDOW


EXISTING (1) 1" CONDUIT
FOR LOOP DETECTOR,
CENTERED ON PICK-UP
WINDOW; REFER TO
ELECTRICAL DRAWINGS

EXISTING CURB, TYP.

EXISTING PUBLIC
RIGHT OF WAY

EXISTING PATIO RAILING

EXISTING LANDSCAPING
AND IRRIGATION

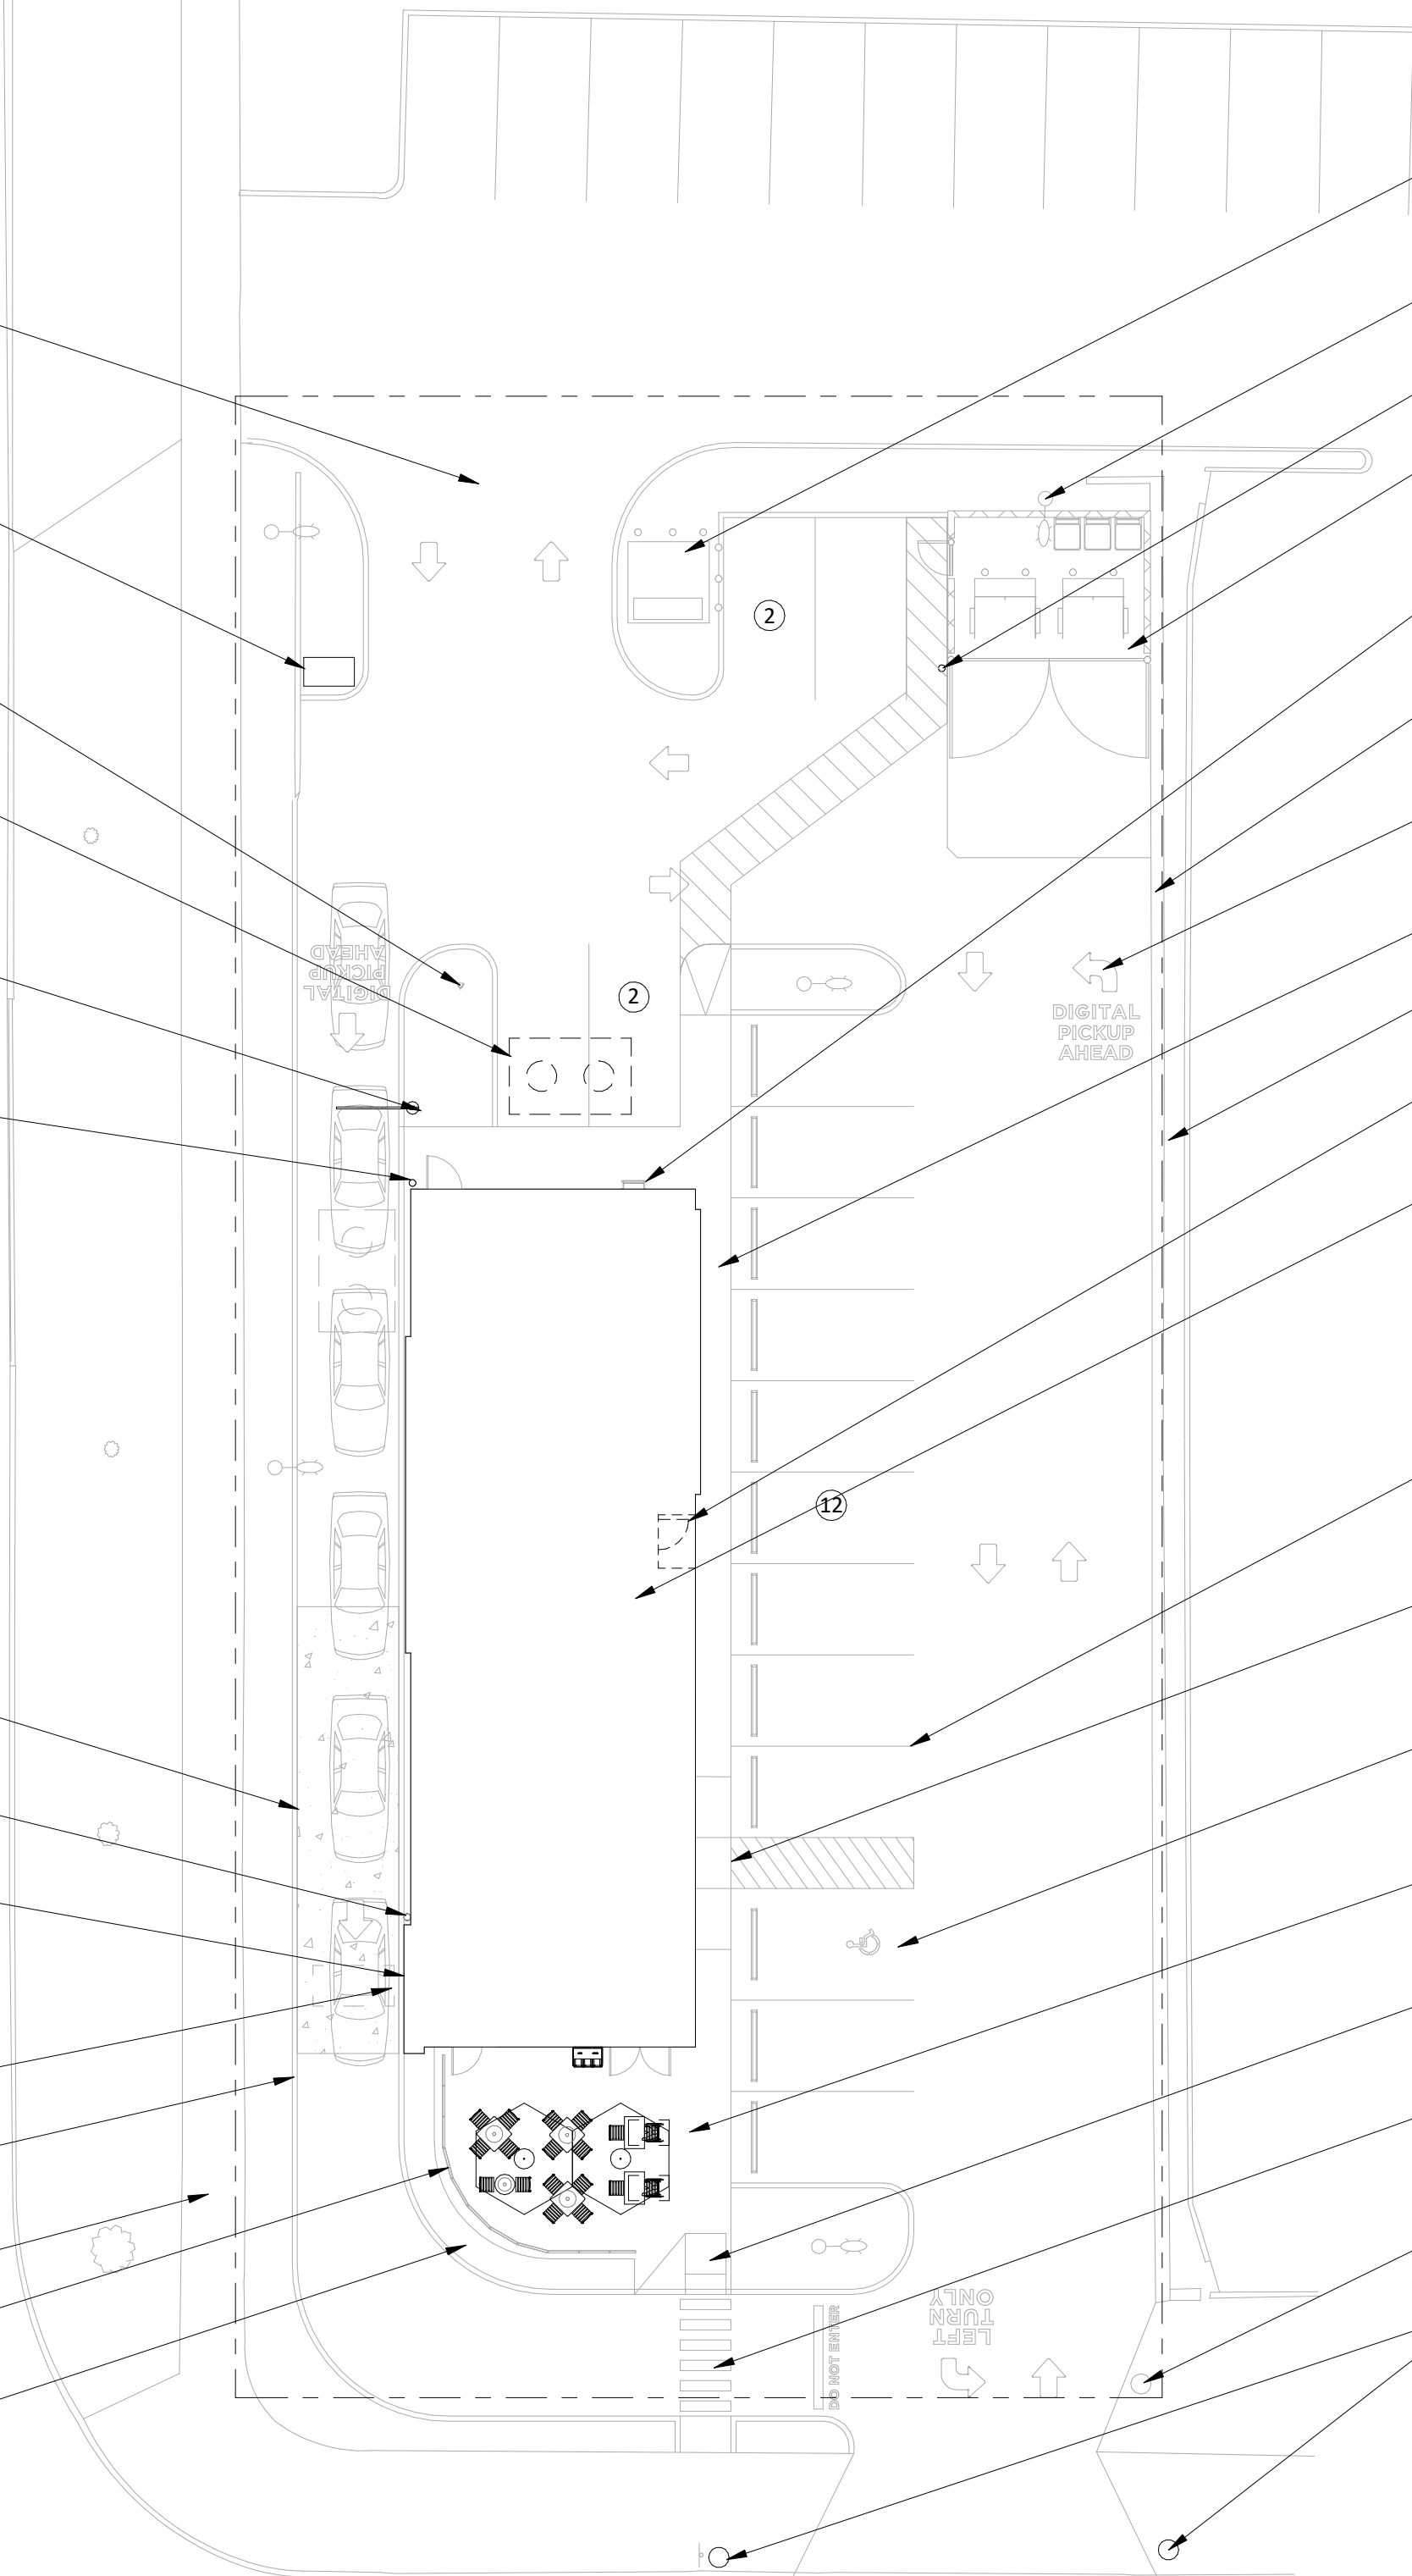

E MCMILLAN STREET

ARCHITECTURAL SITE PLAN
1/16" = 1'-0"

PLUMBING LEGEND

	FLOOR SINK
	FLOOR DRAIN
	TRENCH DRAIN

GENERAL NOTES

1. VERIFY OVERALL INTERIOR DIMENSIONS, INTERIOR COLUMN PLACEMENTS, AND EXTERIOR WALL PENETRATIONS IN FIELD AND NOTIFY ARCHITECT OF ANY DISCREPANCIES PRIOR TO COMMENCEMENT OF CONSTRUCTION.
2. ALL DIMENSIONS ARE TO THE INSIDE FACE OF EXTERIOR WALLS.
3. ALL DIMENSIONS ARE TO THE CENTERLINE OF FIXTURE UNLESS OTHERWISE NOTED.
4. GC TO REVIEW ELECTRICAL PLANS FOR LIGHTING OR POWER STUB LOCATIONS PRIOR TO POURING SLAB.
5. REFER TO "03300 - CAST-IN-PLACE CONCRETE" IN SPECIFICATIONS FOR CONCRETE PATCHING OR INSTALLATION INFORMATION.
6. VERIFY PERIMETER FOUNDATION INSULATION IS EXISTING IN FIELD AND NOTIFY ARCHITECT OF ANY DISCREPANCIES PRIOR TO COMMENCEMENT OF CONSTRUCTION.
7. ALL TILED FLOOR TO MAINTAIN POSITIVE SLOPE TO ALL FLOOR DRAINS OF NOT GREATER THAN 2% SLOPE FOR A 4'X4' AREA U.N.O.

Consultant:

R/A

RedArchitecture

589 W. NATIONWIDE BLVD. SUITE B
COLUMBUS, OHIO 43215 (614) 487-8770

FOR
CONSTRUCTION

COPYRIGHT 2023
THIS DRAWING IS AN INSTRUMENT OF SERVICE
AND AS SUCH REMAINS THE PROPERTY OF
CHIPOTLE MEXICAN GRILL, INC.. PERMISSION FOR
USE OF THIS DOCUMENT IS LIMITED AND CAN BE
EXTENDED ONLY BY WRITTEN AGREEMENT WITH
CHIPOTLE MEXICAN GRILL, INC..



CHIPOTLE MEXICAN GRILL, INC.
PO BOX 182566
COLUMBUS, OH 43218-2566
TELEPHONE: 614.318.2400
INTERNET: WWW.CHIPOTLE.COM

STORE NO.: 4870
WALNUT HILLS
1202 E MCMILLAN STREET
CINCINNATI, OH 45206

Issue Record:

11/03/23	PERMIT SET
05/08/24	CONSTRUCTION SET

Revisions:

1	1/24/24	HEALTH COMMENTS
---	---------	-----------------

Drawn:	Checked:
JTH, PH	TC


Project No.

CMG1144


Contents:

SLAB WORK PLAN


A101a

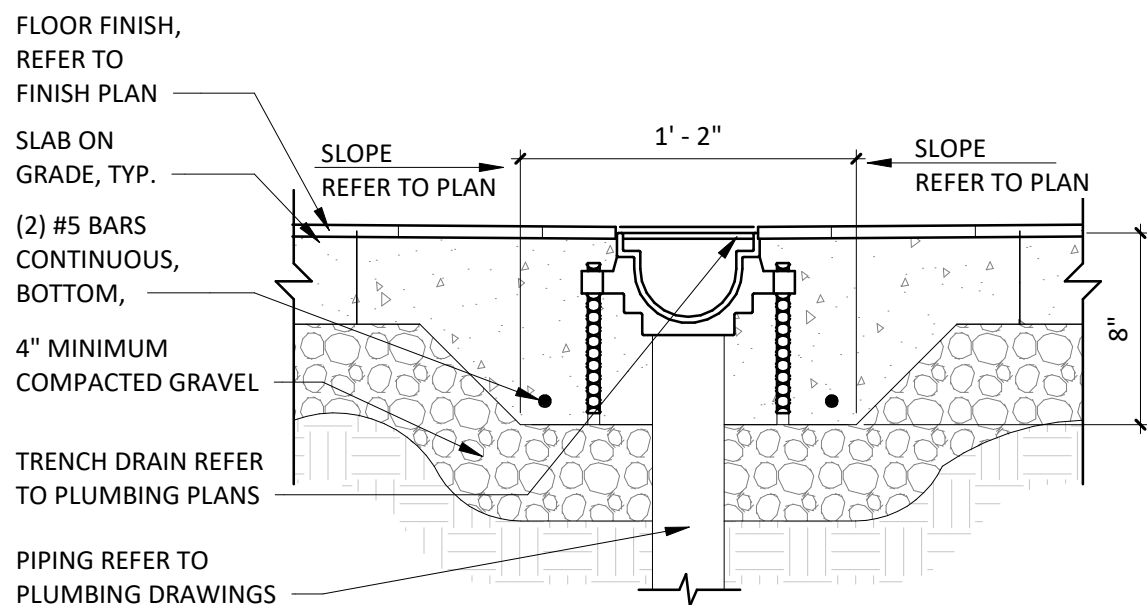


4 TRENCH DRAIN DETAIL
1 1/2" = 1'-0"

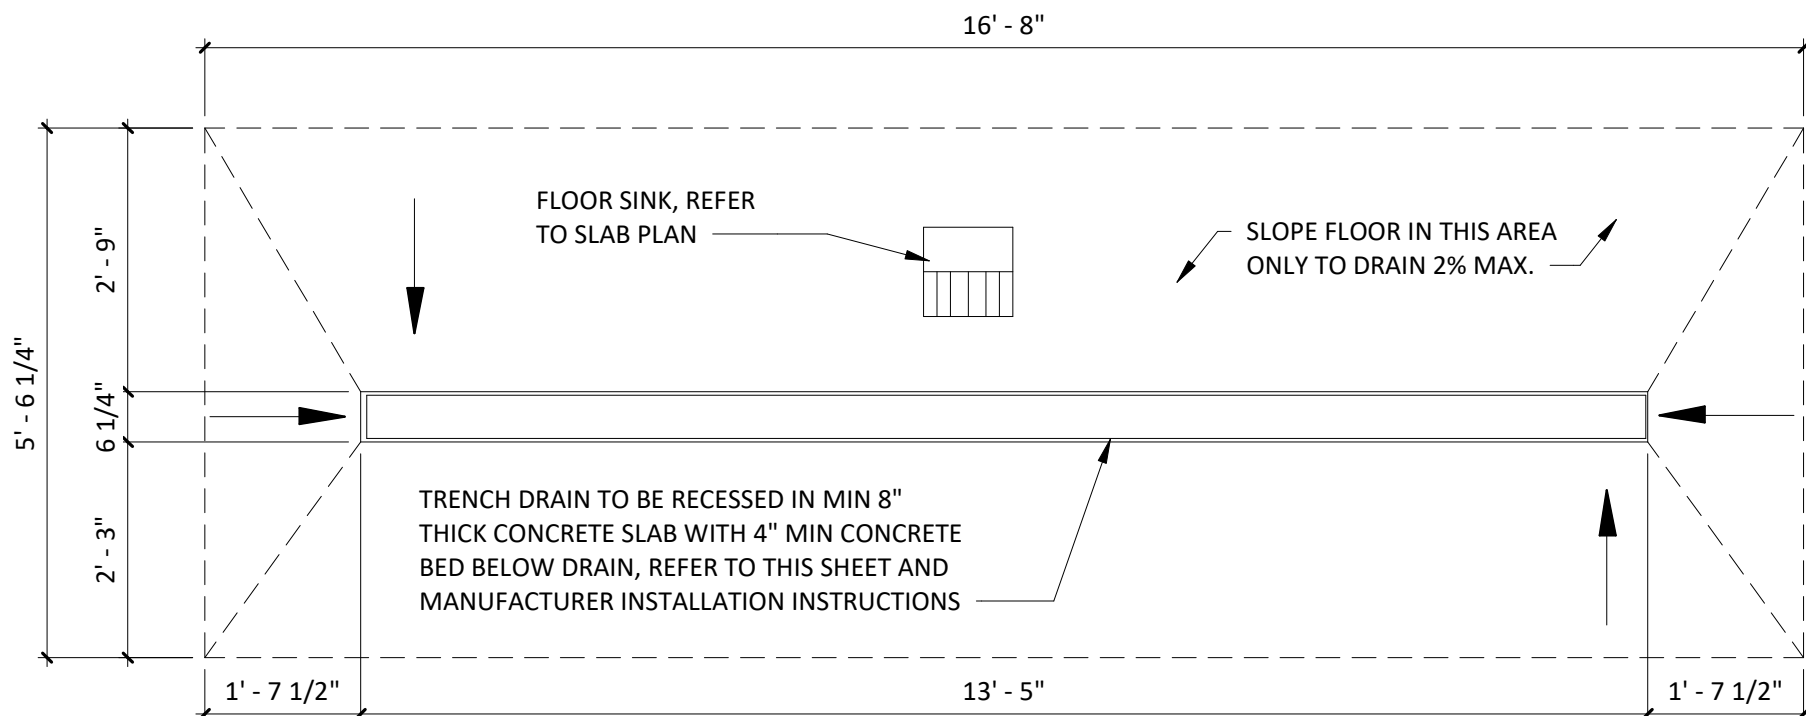

3 TRENCH DRAIN PLAN DETAIL
1/2" = 1'-0"

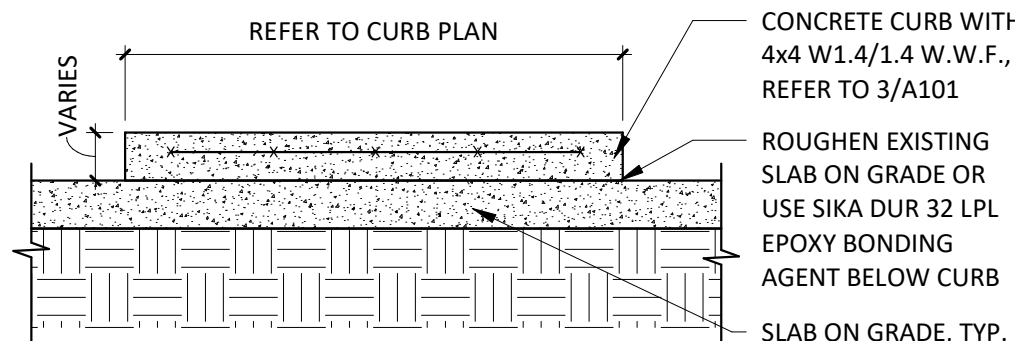

2 CONCRETE CURB DETAIL
3/4" = 1'-0"

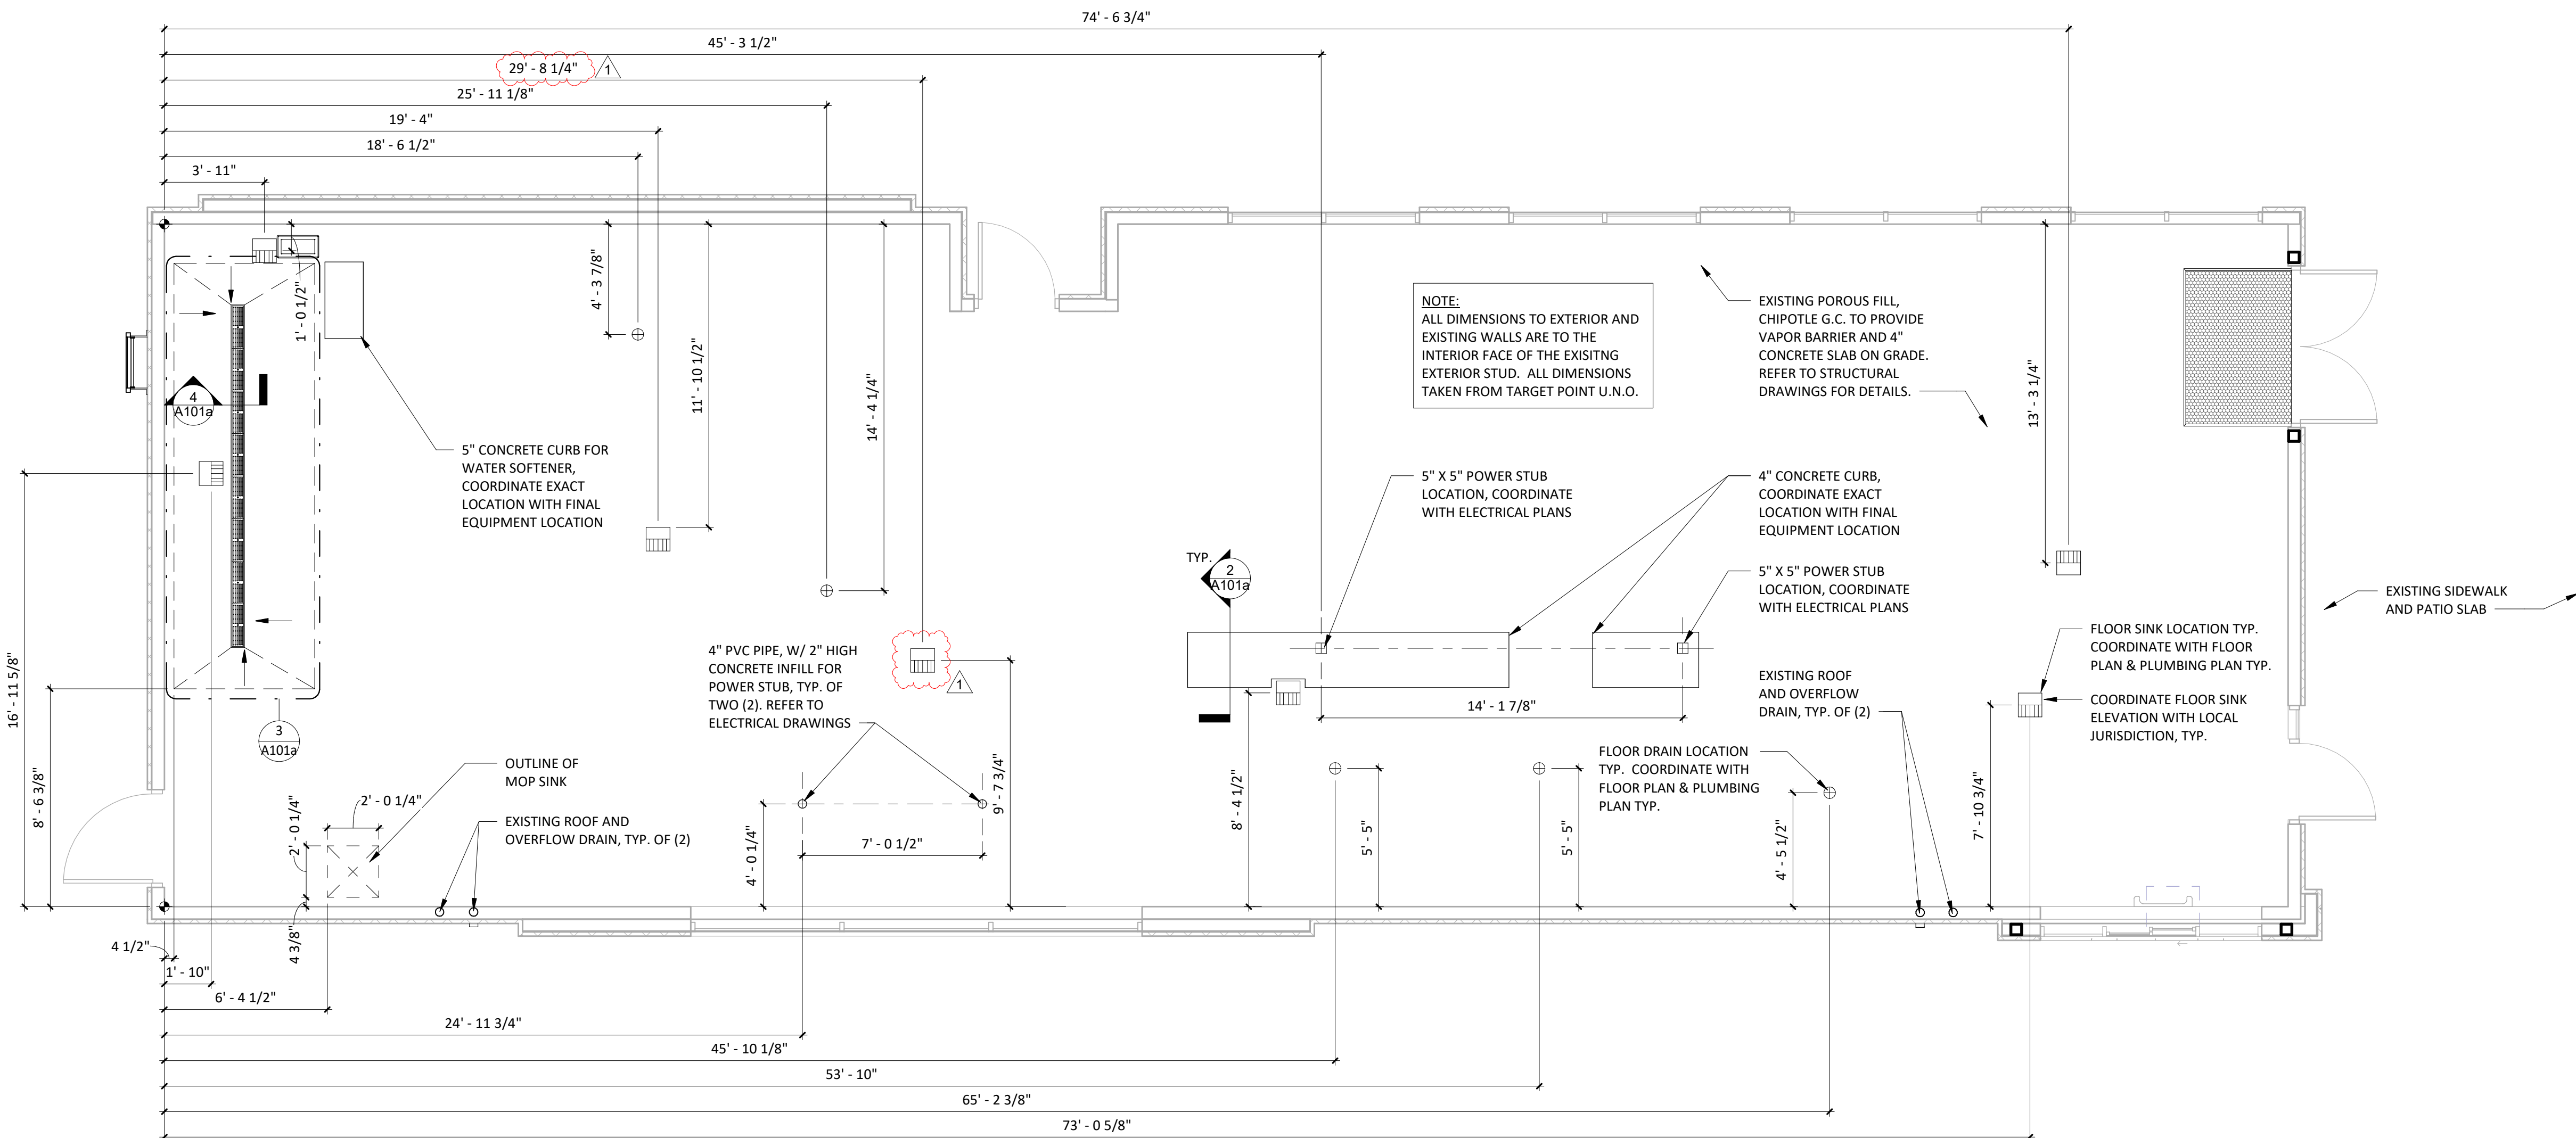

1 SLAB WORK PLAN
1/4" = 1'-0"

REFER TO GENERAL NOTES ON A101a

Consultant:

R/A

Red/Architecture

589 W. NATIONWIDE BLVD. SUITE B
COLUMBUS, OHIO 43215 (614) 487-8770

FOR
CONSTRUCTION

COPYRIGHT 2023
THIS DRAWING IS AN INSTRUMENT OF SERVICE
AND AS SUCH REMAINS THE PROPERTY OF
CHIPOTLE MEXICAN GRILL, INC.. PERMISSION FOR
USE OF THIS DOCUMENT IS LIMITED AND CAN BE
EXTENDED ONLY BY WRITTEN AGREEMENT WITH
CHIPOTLE MEXICAN GRILL, INC..



CHIPOTLE MEXICAN GRILL, INC.
PO BOX 182566
COLUMBUS, OH 43218-2566
TELEPHONE: 614.318.2400
INTERNET: WWW.CHIPOTLE.COM

STORE NO.: 4870

WALNUT HILLS
1202 E MCMILLAN STREET
CINCINNATI, OH 45206

Issue Record:

<u>11/03/23</u>	<u>PERMIT SET</u>
<u>05/08/24</u>	<u>CONSTRUCTION SET</u>

Revisions:

[illegible]

Drawn: JTH,
PH

Checked: TC

Project No.

CMG1144

Contents:


SLAB WORK PLAN


A101b

INTERIOR WALL CONSTRUCTION	
EXTERIOR WALL CONSTRUCTION	
INTERIOR WALL CONSTRUCTION WITH SOUND BATT INSULATION	
WALK-IN COOLER	
DESIGNATES WALLS & SHEATHING TO EXTEND TO DECK	

1.	ALL DIMENSIONS ARE TO FACE OF FRAMING, OR CENTERLINE OF STRUCTURE UNLESS NOTED OTHERWISE.
2.	DASHED CIRCLE IN RESTROOM INDICATES 5'-0" TURNING DIAMETER REQUIRED BY ADA.
3.	REFER TO WALL FINISH SCHEDULE ON A120.
4.	STUD SIZES AS INDICATED ON PLAN.
5.	INTERIOR DOORS ARE 4" OFF OF PERPENDICULAR WALL U.N.O.
6.	IN SITUATIONS WHERE TENANT'S G.C. IS TO PROVIDE TYPE "X" GYP. BD. FOR A RATED ASSEMBLY, THE TYPE "X" GYP. BD. IS REQUIRED TO GO BE NEATH THE SHEATHING AND FINISHES.
7.	SEE SHEET A501 FOR ADDITIONAL SHEATHING BEHIND CERTAIN WALL FINISHES.
8.	SEE A501 FOR DOOR TYPES.
9.	TENANT'S G.C. TO PERFORM LAYOUT OF ENTIRE SPACE PRIOR TO STARTING FRAMING AND REPORT ANY DISCREPANCIES IN NOTED DIMENSIONS TO ARCHITECT AND CHIPOTLE MEXICAN GRILL'S CM PRIOR TO PROCEEDING. FAILURE TO ADHERE TO THESE REQUIREMENTS RESULTING IN ANY REMEDIATION REQUIRED TO MEET DESIGN INTENT WILL BE AT CONTRACTOR'S COST.
10.	SEE A501 FOR WALL TYPES.
11.	PROVIDE DEFLECTION TRACKS AT WALLS WHICH GO TO THE UNDERSIDE OF THE DECKING, REFER TO DETAIL 3/A501
12.	PROVIDE FULL HEIGHT BLOCKING IN WALL FOR ALL SHELVING, TYP.
13.	DENSHIELD TILE BACKER BOARD SHALL NOT BE INSTALLED OVER VAPOR BARRIERS AT EXTERIOR WALLS.
14.	MOISTURE RESISTANT GYP. BD. SHALL BE USED IN RESTROOMS

FOR
CONSTRUCTION

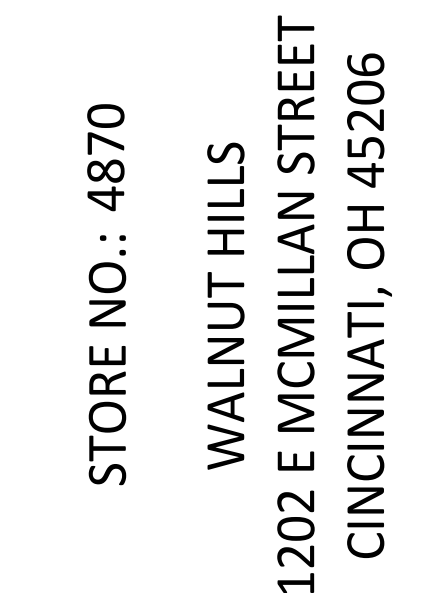
ARCHITECTURAL
FLOOR PLAN

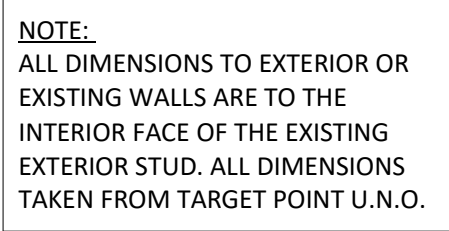

 2
A110

ARCHITECTURAL FLOOR PLAN - DIMENSIONS

1/4" = 1'-0"

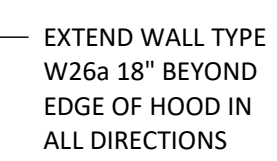


 **ARCHITECTURAL FLOOR PLAN**
1/4" = 1'-0"

1	1-1/2" X 1-1/2" STAINLESS STEEL CORNER GUARDS TO 5'-0" AFF WITH 1-1/2" X 1-1/2" FRP CORNER TRIM ABOVE
2	SCHLUTER-QUADEK METAL CORNER, REFER TO 10&11/A802 & 11/A801.
3	ALUMINUM ENDCAPS, REFER TO 12/A802. FOR WINDOWS, REFER TO 12&13/A802
4	PROVIDE STAINLESS STEEL ON WALL TO 24" ABOVE TOP OF MOP SINK. FLASH BOTTOM EDGE OVER MOP SINK RIM. BEND STAINLESS STEEL AT INSIDE CORNER SO THERE IS NO JOINT, REFER TO 17/A801.
5	NOT USED
6	COOLER WALL PANELS AS PROVIDED BY THE COOLER MANUFACTURER HAVE A 26-GAUGE COATED AND EMBOSSED STEEL FINISH.
7	G.C. TO PROVIDE 18 GAUGE STAINLESS STEEL SHROUD AROUND EXPOSED LINES AT THE ICE MAKER.
8	PROVIDE WATERPROOFING MEMBRANE, REFER TO 4&5/A802. PROVIDE ON INTERIOR OF ALL RESTROOM WALLS, REFER TO 18/A801.
9	PROVIDE QUARRY TILE ON TOP OF CURB FOR SMART SAFE. PROVIDE BULLNOSE TILE TO LAP OVER TOP CUT EDGE OF BASE TILE, REFER TO SHEET 1/802. G.C. TO COORDINATE EXTENT OF QUARRY TILE WITH KES PRIOR TO INSTALLATION.
10	FRP CLOSURE AT COOLER AIR GAP, REFER TO 14/A801
11	NOT USED
12	OUTSIDE CORNER GUARD BY TMS, REFER TO 13/A801
13	ALIGN LOW EDGE OF RENO RAMP WITH FRONT EDGE OF EQUIPMENT CURB AND FACE OF ADJACENT WALL BASE FINISH. AT DOORS, ALIGN LOW EDGE WITH FRONT FACE OF DOOR.
14	SURFACE MOUNTED WALK OFF MAT. INSTALL PER MANUFACTURER'S SPECIFICATIONS; REFER TO 21/A801 FOR DETAILS. EXTENT OF WALK-OFF MAT AREA TO MATCH FLOOR CLEARANCE AREA REQUIRED BY ADA. TAPERED FRAME TO BE INSTALLED OUTSIDE OF ADA AREA.
15	PROVIDE TOP CORNER AT TRANSITION FROM GYP BD CEILING TO FRP WALL REFER TO 9/A210
16	4" PVC PIPE, WITH 2" HIGH CONCRETE INFILL FOR POWER STUB, TYP. OF TWO (2). REFER TO ELECTRICAL DRAWINGS
17	CONCRETE CURB FOR EQUIPMENT, WITH QUARRY TILE BASE AT EXPOSED EDGES
18	EXTENT OF QUARRY TILE FROM KITCHEN, ALIGN TILE WITH EDGE OF DOOR THRESHOLD
19	EXTENT OF RESINOUS FLOORING FROM RESTROOM

1. STONEWOOD WALL PANELS AND WAINSCOT PROVIDED BY TMS, INSTALL BY GC.
2. SPALTED MAPLE PANELS PROVIDED BY TMS, INSTALLED BY GC.
3. GC IS RESPONSIBLE FOR SEQUENCING OF PREWIRING WITH COMPLETION OF INTERIOR FINISHES (GYP. BD. FINISHES).

FLOOR FINISHES		WALL BASE FINISHES		WALL FINISHES		CEILING/DECK FINISHES		DOOR FINISHES	
LGD. #		LGD. #		LGD. #		LGD. #		LGD. #	
F1	POLISHED CONCRETE	B1	BLACK RUBBER, COVELESS	P1	PLYWOOD, VERTICAL GRAIN	C1	OPEN TO STRUCTURE, UNPAINTED	D1	PAINT "BLACK"
F2	QUARRY TILE	B2	QUARRY TILE, COVE	P2	FIBERGLASS REINFORCED PANELS TO 4'-0" AFF (SMOOTH FINISH)	C2	STONEWOOD	D2	PAINT "KNIGHT'S ARMOR"
F3	EXTERIOR CONCRETE	B3	BLACK RUBBER, COVE	P3	GYP BD; PAINT "THIN ICE", EGGSHELL, REFER TO A701 AND A710	C3	GYP BD; PAINT "MOONLIT SNOW"		
F4	SEALED CONCRETE	B4	QUARRY TILE, COVELESS	P4	NOT USED	C4	2X4 VINYL-FACED LAY-IN		
F5	RESINOUS FLOORING	B5	CERAMIC TILE	P5	CERAMIC TILE - WHITE				
				P6	FIBERGLASS REINFORCED PANELS (PEBBLED FINISH)				
				P7	NOT USED				
				P8	CERAMIC TILE - BRONZE ACCENT 3" x 12"				
				P9	SPALTED MAPLE WALL PANEL, HORIZONTAL GRAIN				
				P10	EXISTING STOREFRONT				
				P11	STONEWOOD WALL PANEL				
				P12	EXISTING PREFINISHED BRAKE METAL				

ROOM #	ROOM NAME	FLOOR FINISH	BASE FINISH	WALL FINISH	CEILING FINISH	CEILING HEIGHT	REMARKS
100	MAIN ENTRY	F1	B1		C1	STR	SEE SHEET A701 AND SPECIFICATION SHEETS
101	DINING	F1	B1		C1	STR	SEE SHEET A701 AND SPECIFICATION SHEETS
102	UTENSIL	F1	B1		C2	±8'-1 3/4" / ±9'-1 3/4"	SEE SHEET A701 AND SPECIFICATION SHEETS
103	PASSAGE	F1	B1		C3	9'-6"	SEE SHEET A701 AND SPECIFICATION SHEETS
104	POS	F2	B2/B4		C3 /C4	±9'-0" / ±9'-4"	SEE SHEET A702 AND SPECIFICATION SHEETS
105	ORDERING	F1	B1/B4/B5		C1/C3	STR / ±9'-0"	SEE SHEET A701 AND SPECIFICATION SHEETS
106	SERVING	F2	B2		C3	±9'-0"	SEE SHEET A702 AND SPECIFICATION SHEETS
107	COOKING	F2	B2		C3 /C4	±9'-0" / ±9'-4"	SEE SHEET A702 AND SPECIFICATION SHEETS
108	KITCHEN	F2	B2		C3	9'-6"	SEE SHEET A702 AND SPECIFICATION SHEETS
109	OFFICE	F2	B2		C4	9'-0"	EXTEND SHEATHING TO STRUCTURE
110	COOLER	F2	B2		STR	STR	CEILING HEIGHT & FINISHES PER MANUFACTURER
111	UNISEX 1	F5	B3		C3	8'-0"	SEE SHEET A710 AND SPECIFICATION SHEETS
112	UNISEX 2	F5	B3		C3	8'-0"	SEE SHEET A710 AND SPECIFICATION SHEETS
113	PATIO	F3	-		-	-	-

 


1. REFER TO SHEETS A131 AND A132 FOR EQUIPMENT LIST AND FURNITURE SCHEDULE.
2. ALL DIMENSIONS ARE TO FACE OF FRAMING, EDGE OF EQUIPMENT OR CENTERLINE OF EQUIPMENT UNLESS NOTED OTHERWISE.
3. ALL FURNITURE TO BE SQUARE/PARALLEL TO TENANT SPACE/WALLS AS SHOWN ON PLANS

R/A

589 W. NATIONWIDE BLVD. SUITE B
COLUMBUS, OHIO 43215 (614) 487-8770

COPYRIGHT 2023
THIS DRAWING IS AN INSTRUMENT OF SERVICE
AND AS SUCH REMAINS THE PROPERTY OF
CHIPOTLE MEXICAN GRILL, INC.. PERMISSION FOR
USE OF THIS DOCUMENT IS LIMITED AND CAN BE
EXTENDED ONLY BY WRITTEN AGREEMENT WITH
CHIPOTLE MEXICAN GRILL, INC..

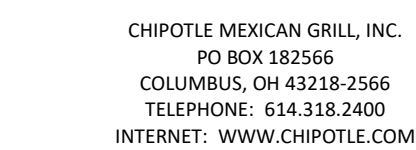

Issue Record:	
11/03/23	PERMIT SET
05/08/24	CONSTRUCTION SET
Revisions:	
1/24/24	HEALTH COMMENTS
Drawn:	Checked:
JTH,	TC
PH	
Project No.	
CMG1144	
Contents:	

A130



NOTE:
ALL DIMENSIONS TO
EXTERIOR OR EXISTING WALLS
ARE TO THE INTERIOR FACE OF
THE EXISTING EXTERIOR STUD

KITCHEN EQUIPMENT LIST

ITEM #	DESCRIPTION	MANUFACTURER	MODEL NO.	QTY	SUPPLIED BY	INSTALLED BY	UTILITY				REMARKS
							ELEC	GAS	WATER	SEWER	
1.1	Sneeze Guard Serve Line 12 Pan (Right)	BSI	Custom-R	1	TMS	TMS/GC					
1A	Front Serve Line - 12 Pan - RTD - POS Right	Delfield	12 Pan Serve Line POS RTD_241x38.5in (Right)	1	KES	KES; GC	●			●	Installed On Concrete Curb
2A	Tortilla Warmer	Caliente Industries	A2	2	KES	KES	●				GC To Store In Walk-In Cooler Until Final Installation
6	Cup Dispenser	Dispense-Rite	CHIP-ECL-3B	1	KES	KES; GC					Installed At POS Counter
7B.1	Upright Beverage Cooler, Single Door, Hinge Left	Varies	Varies - Solid Door	1	KES	KES	●				
7B.2	Upright Beverage Cooler, Single Door, Hinge Right	Varies	Varies - Solid Door	2	KES	KES	●				
8.3	M4.5 Chip Shelf	Trimark	Custom	1	KES	KES					
10	Blender	Vitamix	748	1	KES	KES	●				GC To Store In Walk-In Cooler Until Final Installation
11	Carving Station - 77x34in - Horizontal Well - Right	Delfield	77x34in Carving Station-RT	1	KES	KES	●				
12	Undercounter Refrigerator	Varies	Varies	1	KES	KES	●				
13	Grill 48in - Natural Gas - Divider Left	Woodstone	WS-PL-48-36-4-CT-Left	1	KES	KES	●	●			
13.1	Woodstone Grease Splash Guard	Nationwide Fab; Marlo Mfg	CHP-GCG-GSG	1	KES	KES					Verify If Required
14	Range 6 Burner - Natural Gas	Garland	U36-6S	1	KES	KES		●			
15	Woodstone Grill Stand 48x31in - Divider Left	Woodstone	000-PL-STAND-CASTER	1	KES	KES					
16	Fryer - Gas - Standard Efficiency	Varies	Varies	1	KES	KES	●	●			Mounted On Legs, G.C. To Pin Front Legs To Floor
16.1	Grease Caddy	Varies	Chipotle Grease Caddy - RH	1	KES	KES					
17	Cook Line Stand Off - 72x6	Nationwide Fab; Marlo Mfg	CHP-6WS-6	2	KES	KES					Mount Top of Flat Surface at 33" AFF, Install Screws at Each Stud Location, Provide Blocking To Mount To Wall
18B	Gas Rice Cooker	Woodstone	WS-RGC-60	1	KES	GC	●	●			Final Connection by GC. RE:Mechanical Drawings
19	Rice Cooker Stand - Left	Nationwide Fab; Marlo Mfg	CHP-RCS-42ES-34	1	KES	KES					
22	Prep Sink - Corner - Left	Trimark	S1-122x34-US-FF-L	1	KES	GC				●	
22.1	Prep Sink Faucet Big Flow Faucet	T&S	B-0293-01	1	KES	GC			●		
22.2	Prep Sink Vegetable Wash Faucet	T&S	B-0730	1	KES	GC			●		GC To Provide Connection For Chemical Dispensing Equipment
22.3	Prep Sink Drain Assembly	T&S	B-3950	1	KES	KES; GC				●	
23	4 Shelves - 120in Prep Sink	Amco	CHPPS120	1	KES	KES					Mount Bottom Of Standard At 50" AFF. Provide Plywood Blocking To Mount To Wall.
23A	2 Shelves - 30in	Amco	Custom	1	KES	KES					Mount Bottom Of Standard At 50" AFF. Provide Plywood Blocking To Mount To Wall.
24.3	Hand Sink Wall Mounted - Splash Both	Universal Stainless	EHS-1RL-NF	3	KES	GC				●	Provided with B-0199-06-F10, 1.0 GPM Aerator, Provide Plywood Blocking To Mount To Wall
24.5	Kitchen Hand Sink Faucet Splash Mount	T&S	B-1146-04	3	KES	GC			●		
25	Rice Prep Table Island 66x34	Nationwide Fabrication; Marlo Mfg	Custom Table 66x34in	1	KES	KES					
26	Hot Holding Cabinet - Double Door (Rice)	Food Warming Equipment (FWE)	HLC-1220-8-8-CHP	1	KES	KES	●				
29.2	Dish Sink Add-A-Faucet w/ Pre-Rinse	T&S	B-1033-12CRBJSK Substitute Sprayer B-0107-J-SWW	1	KES	GC			●		
29.3	Dish Sink Drain Assembly	T&S	B-3950	3	KES	KES; GC				●	
29.4	Dish Sink Chemical Faucet	T&S	B-2345-01-XX	1	KES	GC			●		GC To Provide Connection For Chemical Dispensing Equipment
29B	3 Comp Sink - 18x24in Bowls - 111 3/4in	Nationwide Fabrication; Marlo Mfg	S3-30x111.75x36.5-FF	1	KES	GC				●	
30	Shelving System - 3 Comp Sink	Amco	WST1879S	1	KES	KES					Mount bottom of Standard At 56"AFF. Provide Plywood Blocking
30.2	Shelving System - Dish Table	Amco	WST1879S	2	KES	KES					Mount bottom of Standard At 56"AFF. Provide Plywood Blocking. Mount Tight To Dish Machine
31.7	Drying Racks 23x48x85in - With Vented Aluminum Covers	Varies	Custom	1	KES	KES					Mount Bottom Of Standard At 12" AFF. Provide Plywood Blocking To Mount To Wall
32.1A	Ice Maker - Remote Condenser	Hoshizaki	URC-5F	1	KES	KES	●				Condensing Units To Be Secured To The Roof Per Code By GC
32.1C	Ice Maker - Remote Condenser	Hoshizaki	URC-14F	1	KES	KES	●				Condensing Units To Be Secured To The Roof Per Code By GC
32.1E	Ice Maker - Remote Condenser	Scotsman	ERC1111-1	1	KES	KES	●				Condensing Units To Be Secured To The Roof Per Code By GC
32.2A	Ice Maker - Storage Bin	Hoshizaki	B500SF	1	KES	KES				●	
32.3	Icemaker- Filter	Cuno	Bev 190	3	KES	KES			●		
32.4	Ice Maker - Scale Inhibitor	Cuno	CF5440-HT	3	KES	KES			●		
32C	Ice Maker Mounted On Soda Machine - Air Cooled	Hoshisaki	KMD-530MAJ	1	KES	KES	●		●	●	Drain Ice Maker to Floor Sink, RE: Mech. Refrigeration By Tenant.
32D	Ice Maker Mounted On Soda Machine - Remote Air Cooled	Hoshisaki	KMD-530MRJ	1	KES	KES	●		●	●	Drain Ice Maker to Floor Sink, RE: Mech. Refrigeration By Tenant.
32M	Ice Maker For B.O.H. Ice Bin	Hoshizaki	KM-901MRJ	1	KES	KES	●		●		Drain Ice Maker to Floor Sink, RE: Mech. Refrigeration By Tenant.
33	Walk In Cooler 9x12x9ft 6in - Standard	Manitowoc/Norlake	CHP912SL-RS	1	WCS	GC	●			●	Refer To Plumbing and Mechanical Drawings; Refrigeration By Tenant; Remote Exterior Compressor Unit To Be Secured To Roof Per Code By GC
34	Walk-In Cooler Shelving System - 9x12x9	Cambro (Camshelving)	CHP912EL	1	KES	KES					
35.2	Dry Storage Racks 23x96x85in	Varies	Custom	2	KES	KES					Mount Bottom Of Standard At 12" AFF. Provide Plywood Blocking To Mount To Wall.
37	Mop Sink Faucet	T&S	B-0660-BSTR	1	KES	GC			●		
37.1	Mop Sink Chemical Faucet	T&S	B-2345-01-XX	1	KES	GC			●		GC To Provide Connection For Chemical Dispensing Equipment
38	6 Shelves - Chemical Storage Rack	Varies	Custom	1	KES	KES					Mount Bottom Of Standard At 12" AFF. Provide Plywood Blocking To Mount To Wall.
39B	DML 2.0 130in – Left – W/POS & Cash Drawer	Franke/Delfield	DML 2.0_LT-130x39	1	KES	KES	●			●	
39B.1	DML 2.0 Wall Trim Package	Franke/Delfield	DML 2.0 Trim Kit	1	KES	KES					
40D	Holding Shelf	Trimark	TGS-39X20X80-B	1	KES	KES	●				
41.5	DML 2.0 Shelving - 130in - Top Shelf	Franke/Delfield	CH000A32	1	KES	KES					Mount Bottom Of Shelf At 74 1/2" AFF. Provide Plywood Blocking To Mount To Wall.
41.6	DML 2.0 Shelving - 130in - Bottom Shelf	Franke/Delfield	CH000A34	1	KES	KES					Mount Bottom Of Lowest Portion Of Shelf At 54 1/2" AFF. Provide Plywood Blocking To Mount To Wall.
42	Shelving System Under Counter Beverage Station	ISS	WST1810CLR	1	KES	KES					Mounted on (4) casters, All casters to be swivel type, Front (2) casters to have brake, Located under utensil counter
43	Beverage Cooler Backbar 36in	Varies	Varies	1	KES	KES	●			●	
50	Food Processor	Sammic	CA-31	1	KES	KES					
55	Filler Table - 24x34in	Trimark	TS-24x34x36-US-C	1	KES	KES					
56	Beverage Table - Chipotleane	Trimark	TS-36x92.5x36	1	KES	GC	●			●	
61B	Dish Machine (w/Pump)	Hobart	AM16SCB	1	KES	KES	●		●	●	
62B	Dish Table 30x30	Trimark	CDT-30X30X36.5-B	1	KES	GC					
65	Utility Cart (Not Shown)	Select Stainless	30SU-22-14-C4-TUBS-CUSTOM	1	KES	GC					Provided As Part Of The WIC Shelving
66A	Drop-Off Table - 29x30in	Trimark	TS-29x30x31-US-C	1	KES	KES					
67	Refrigerated Counter Case, Self-Serve	Structural Concepts	CO3324R-UC	1	KES	KES					
69B	M4.0 - Simplicity Bubbler Mini-Quad	Crathco	CS-4E-16	1	KES	GC	●			●	
70	Speed Fill Faucet	T&S	B-0432 MOD	1	KES	GC			●		
71	Quesadilla Press	Turbochef	Sota Touch	1	KES	KES	●				
73A	50" TurboChef Table	Trimark	50X36X36	1	KES	KES					
74	Shelving - Under Counter - 12x36x29in	Metro	Custom	1	KES	KES					

Consultant:



Red/Architecture

589 W. NATIONWIDE BLVD. SUITE B
COLUMBUS, OHIO 43215 (614) 487-8770

FOR
CONSTRUCTION

COPYRIGHT 2023
THIS DRAWING IS AN INSTRUMENT OF SERVICE
AND AS SUCH REMAINS THE PROPERTY OF
CHIPOTLE MEXICAN GRILL, INC.. PERMISSION FOR
USE OF THIS DOCUMENT IS LIMITED AND CAN BE
EXTENDED ONLY BY WRITTEN AGREEMENT WITH
CHIPOTLE MEXICAN GRILL, INC..



CHIPOTLE MEXICAN GRILL, INC.
PO BOX 182566
COLUMBUS, OH 43218-2566
TELEPHONE: 614.318.2400
INTERNET: WWW.CHIPOTLE.COM

STORE NO.: 4870
WALNUT HILLS
1202 E MCMILLAN STREET
CINCINNATI, OH 45206

Issue Record:

11/03/23 PERMIT SET
05/08/24 CONSTRUCTION SET



Revisions:

Drawn: JTH,
PH
Checked: TC

Project No.

CMG1144

Contents:

EQUIPMENT
SCHEDULE

A131

MISC. EQUIPMENT LIST

TAG	DESCRIPTION	QTY	SUPPLIED BY	INSTALLED BY	UTILITY				REMARKS
					ELEC	GAS	WATER	SEWER	
1	Point of Sale Display	1	TMS	GC					Installed at POS Station
2	Point-Of-Sale System	2	T	TCC					Coordinate Requirements With Tenant and Elec. Drawings
4A	B-Rate (Standard Safe)	1	TS	GC					Installed in Office
4C	Smart Safe	1	TSS	TSS	●				To Be Installed On Curb Under Serveline, Bolt to Curb Under Serveline POS
5B	Soda Dispenser - With Air-Cooled Ice Maker	1	SPS	SPS	●			●	Drain to Floor Sink, Tenant Millwork Supplier to Provide (2) Adjustable Legs to Support Dispenser From Under The Utensil Counter
5C	Soda Dispenser - With Remote Air-Cooled Ice Maker	1	SPS	SPS	●			●	Drain to Floor Sink, Tenant Millwork Supplier to Provide (2) Adjustable Legs to Support Dispenser From Under The Utensil Counter
6	Soda System Syrup Rack with Carbonator on Stainless Steel Shelf	1	SPS	SPS	●		●		
7A	Bulk CO2 Tank	1	CO2	CO2	●				GC To Secure Cylinders To Wall With Grade 30 Galvanized Steel Chain At 2/3 The Height Of The Cylinder. Attach To Wall With Stainless Steel Quick Link And Screw Eye
8A	Gas Tankless Water Heater	2	GC	GC		●	●	●	Refer to MEP Drawings
9	Mop Sink, See Plumbing Drawings	1	GC	GC			●	●	See Plumbing Drawings
10	Touch-Free Soap Dispenser	3	WA	GC					
10.1	Hand Sanitizer Dispenser	3	WA	GC					
11	Paper Towel Dispenser, Bobrick B262	3	WA	GC					Provide Plywood Blocking to Mount to Wall
12	First Aid Kit	1	T	GC					Confirm Location With Chipotle CM Prior To Installation
13A	M4.0 - Artwork Panel - Plaster 2Hx, Start Pattern At Column 1	1	TAS	GC					Provide Plywood Blocking to Mount to Wall
14	License Frame	1	T	GC					Provide Plywood Backing In Wall At License Frame Location, Refer To Arch. Floor Plans And Elevations For License Frame Location.
16A	Fire Extinguisher Type ABC - B456	3	GC	GC					Mount in locations specified by the Fire Marshal. Provide plywood backing at specified locations.
16B	Fire Extinguisher Type K	1	GC	GC					Mount in locations specified by the Fire Marshal. Provide plywood backing at specified locations.
19	Hat & Coat Strips (Not Shown)	1	WA	GC					Provide Plywood Blocking to Mount to Wall
20	2-Drawer File Cabinet, By Tenant	1	T	T					By Tenant
22	Water Softener	1	KES	GC			●	●	See MEP Sheets For Details
24	LaunchPort Wall Station	2	T	GC	●				Tablet By Tenant, Refer to Electrical Drawings
28	Mop Strip (Not Shown)	1	T	GC					Provide Plywood Backing To Mount To Wall, 2 Hole At Mop Basin and 6 Hole In Kitchen
31A	21inx31in Menu System	1	TMB	GC					
32	CO2 Alarm	1	CO2AS	GC	●				Refer to Electrical Drawings for Additional Details
33A	M4.0 - Pick-Up Sign - Single Faced - Flush Mounted - Face	1	TSV	GC					

FURNITURE LIST

TAG	DESCRIPTION	QTY	SUPPLIED BY	INSTALLED BY	UTILITY				REMARKS
					ELEC	GAS	WATER	SEWER	
1E	M4.0 - Table 24x24in - Rectangular Base	1	TMS	GC					
1F	M4.0 - Table 24x42in, Rectangular Base (Accessible)	8	TMS	GC					See Detail On A130
2	M4.0 - Table 24x42in, Bar Height	2	TMS	GC					
3C.1	M4.0 - Dining Room Chair	27	TMS	GC					
3E	M4.0 - Bar Stool - Fixed	8	TMS	GC					Align Seat With Seam Perpendicular To Table Edge
4Q.1	M4.0 - Booth - Single - 42"	2	TMS	GC					
4Q.6	M4.0 - Booth - Single - 93 3/4"	1	TMS	GC					
6B	M4.0 - Beverage Counter - No Trash - 4" Splash - 113"	1	TMS	GC				●	Coordinate Floor Drain Installation with Utensil Counter Installation
11	Office Chair, By Tenant	1	T	T					By Tenant
12	Patio Chair - Bistro	18	KES	GC					Provided by EMU America, Contact: Carol Hughes (303-744-3200)
13A	24in Round Bistro Table	1	KES	GC					Provided by EMU America, Contact: Carol Hughes (303-744-3200)
13B	30in Square Bistro Table	3	KES	GC					Provided by EMU America, Contact: Carol Hughes (303-744-3200)
14A	3 Bin Trash/Recycling Surround - Exterior	1	TMS	GC					Bins Provided by Tundra in Smallwares Package
14C	M4.0 - 3 Bin Trash/Recycling Surround - Interior	1	TMS	GC					Bins Provided by Tundra in Smallwares Package
15	Patio Umbrella	2	KES	GC					
16	Accessible Patio Table	2	KES	GC					Provided By EMU America, Contact: Carol Hughes (303-744-3200)
17A.2	MOPUS Shelving - 44"	1	TMS	GC					GC To Provide Blocking In Walls At The Ends Of The MOPUS Shelf To Secure Shelves, Wood Edge Of The Shelves To Face The Dining Room

Consultant:



Red/Architecture

589 W. NATIONWIDE BLVD. SUITE B
COLUMBUS, OHIO 43215 (614) 487-8770

FOR
CONSTRUCTION

COPYRIGHT 2023
THIS DRAWING IS AN INSTRUMENT OF SERVICE
AND AS SUCH REMAINS THE PROPERTY OF
CHIPOTLE MEXICAN GRILL, INC.. PERMISSION FOR
USE OF THIS DOCUMENT IS LIMITED AND CAN BE
EXTENDED ONLY BY WRITTEN AGREEMENT WITH
CHIPOTLE MEXICAN GRILL, INC..



CHIPOTLE MEXICAN GRILL, INC.
PO BOX 182566
COLUMBUS, OH 43218-2566
TELEPHONE: 614.318.2400
INTERNET: WWW.CHIPOTLE.COM

STORE NO.: 4870
WALNUT HILLS
1202 E MCMILLAN STREET
CINCINNATI, OH 45206

Issue Record:

11/03/23 PERMIT SET
05/08/24 CONSTRUCTION SET

Revisions:

Drawn:

JTH,
PH

Checked:

TC

Project No.

CMG1144

Contents:

EQUIP. & FURNITURE
SCHEDULE

A132

HVAC EQUIPMENT

NOTE: UTILITIES BY GC, REFER TO MECHANICAL DRAWINGS.

DESCRIPTION	SUPPLIED BY	INSTALLED BY	UTILITY				REMARKS
			ELEC	GAS	WATER	SEWER	
EXHAUST FANS & CURBS	HS	GC					CURB FURNISHED BY HS, INSTALLED BY GC
MAKE UP AIR UNIT & CURBS	HS	GC					CURB FURNISHED BY HS, INSTALLED BY GC
ROOF TOP UNITS & CURBS	HES	GC					CURB FURNISHED BY HS, INSTALLED BY GC
TEST & BALANCE SYSTEM	TAB	-					FURNISH HVAC TEST & BALANCE PER TENANT'S NATIONAL ACCOUNT PROGRAM.

GENERAL NOTES

- SEE STRUCTURAL DRAWINGS FOR LOCATIONS AND SIZE OF STRUCTURAL ROOF REINFORCEMENTS.
- SEE MECHANICAL PLANS FOR ROOF TOP EQUIPMENT.
- COORDINATE ALL ROOF PENETRATIONS, FLASHING, AND REPAIR W/ TENANT ROOF TOP EQUIPMENT PRIOR TO COMMENCEMENT OF WORK.
- DIMENSIONS FOR ROOF TOP EQUIPMENT WITH CURBS IS TO THE OUTSIDE FACE OF THE CURB. DIMENSIONS FOR EQUIPMENT WITHOUT CURBS ARE TO THE CENTER OF THE UNIT. ALL DIMENSIONS ARE FOR REFERENCE ONLY. ROOFING CONTRACTOR TO ADJUST AS NECESSARY IN FIELD. CONTACT ENGINEERING CONSULTANTS FOR ANY MAJOR MODIFICATIONS TO LAYOUT.
- JOISTS FOR SHELL BUILDING ARE TO BE DESIGNED FOR THE RTU WEIGHTS AND PLACEMENT EXHIBITED. IF LOCATION OR ORIENTATION OF A UNIT MUST CHANGE, NOTIFY ARCHITECT IMMEDIATELY.
- SEE M700 FOR PENETRATION DETAILS AT RTUS AND THE EXHAUST FAN.
- PROVIDE INSULATED CURBS FOR ALL EQUIPMENT IN EXPOSED DECK AREA ONLY.
- PROVIDE TAPERED INSULATION CRICKET AT ALL EQUIPMENT CURBS.
- LOCATE ALL UNITS SO DUCT DROPS BETWEEN TRUSS JOISTS. NOTIFY ARCHITECT IMMEDIATELY IF ANY UNITS NEED TO SHIFT FROM PLAN LOCATION SHOWN.

Consultant:

R/A

Red Architecture

589 W. NATIONWIDE BLVD. SUITE B
COLUMBUS, OHIO 43215 (614) 487-8770

FOR
CONSTRUCTION

COPYRIGHT 2023
THIS DRAWING IS AN INSTRUMENT OF SERVICE
AND AS SUCH REMAINS THE PROPERTY OF
CHIPOTLE MEXICAN GRILL, INC. PERMISSION FOR
USE OF THIS DOCUMENT IS LIMITED AND CAN BE
EXTENDED ONLY BY WRITTEN AGREEMENT WITH
CHIPOTLE MEXICAN GRILL, INC..



CHIPOTLE MEXICAN GRILL, INC.
PO BOX 182566
COLUMBUS, OH 43218-2566
TELEPHONE: 614.318.2400
INTERNET: WWW.CHIPOTLE.COM

STORE NO.: 4870
WALNUT HILLS
1202 E MCMILLAN STREET
CINCINNATI, OH 45206

Issue Record:

11/03/23 PERMIT SET
05/08/24 CONSTRUCTION SET

Revisions:

2 4/25/24 PLAN REVIEW
COMMENTS

Drawn:

JTH,
PH

Checked:

TC


Project No.

CMG1144

Contents:

ARCHITECTURAL
ROOF PLAN

A140

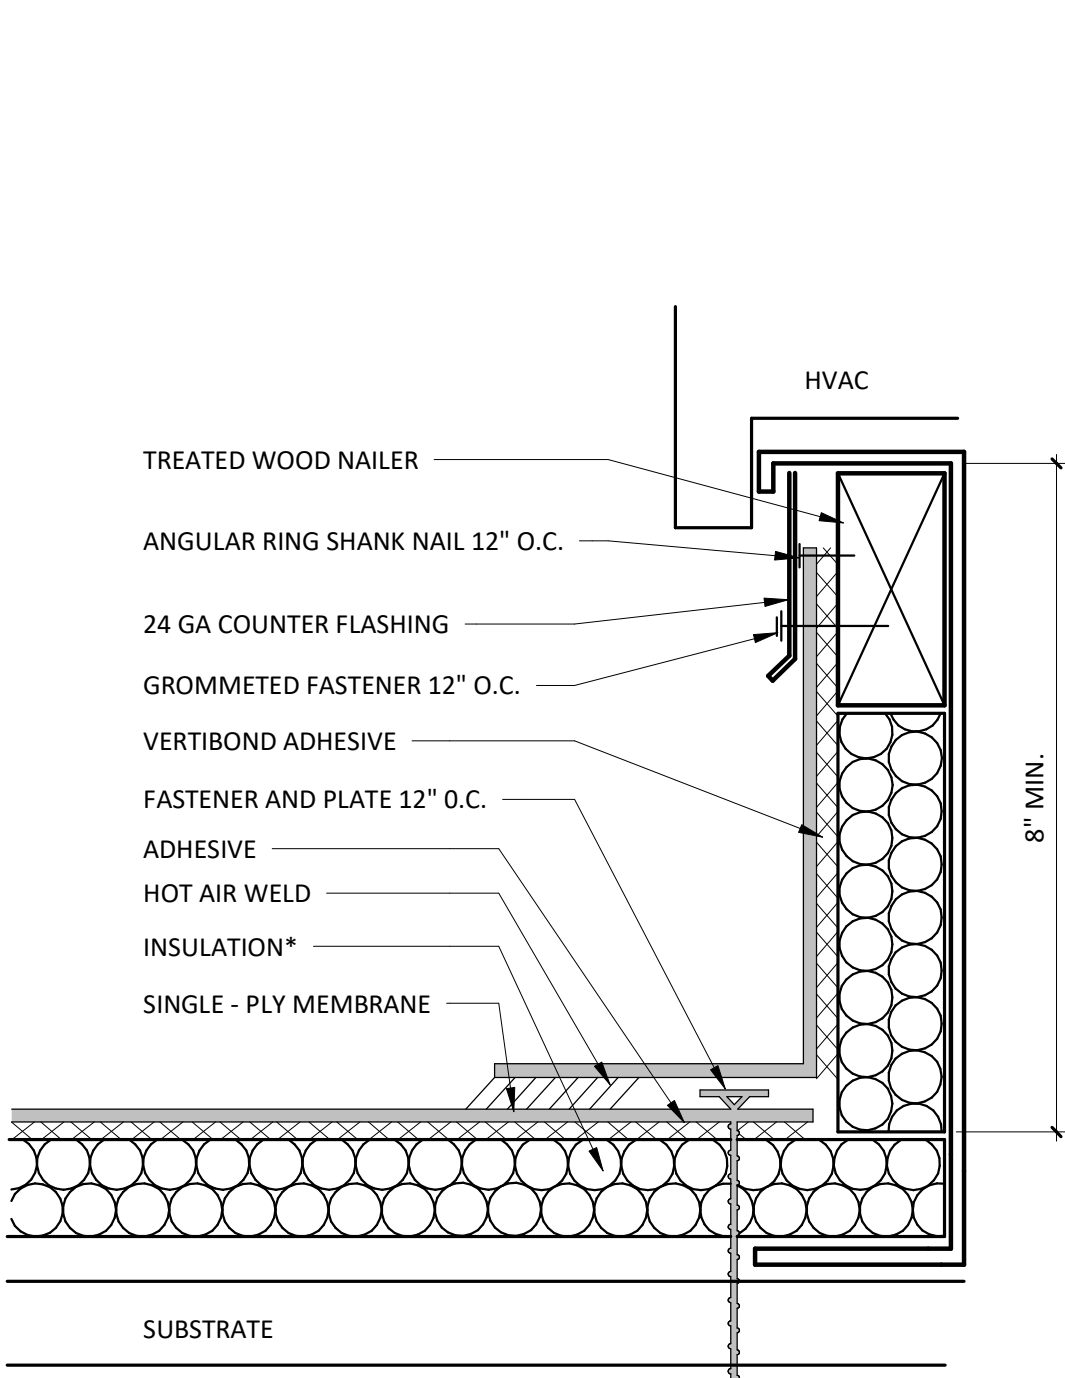


NOTES:

- INSTALLATION TO BE COMPLETED IN ACCORDANCE WITH MANUFACTURERS SPECIFICATIONS.
- DO NOT SCALE DRAWINGS.
- USE PREFABRICATED OUTSIDE CORNERS.
- INSULATION MUST BE SECURELY FASTENED.
- *GLASS - FACED POLYISO INSULATION IS OPTIONAL AND MAY NOT BE REQUIRED ON EVERY PROJECT. IF INSULATION IS NOT REQUIRED, THE MEMBRANE MUST BE ADHERED TO AN APPROVED SURFACE.

CURB FLASHING

3
A140
1/2" = 1'-0"

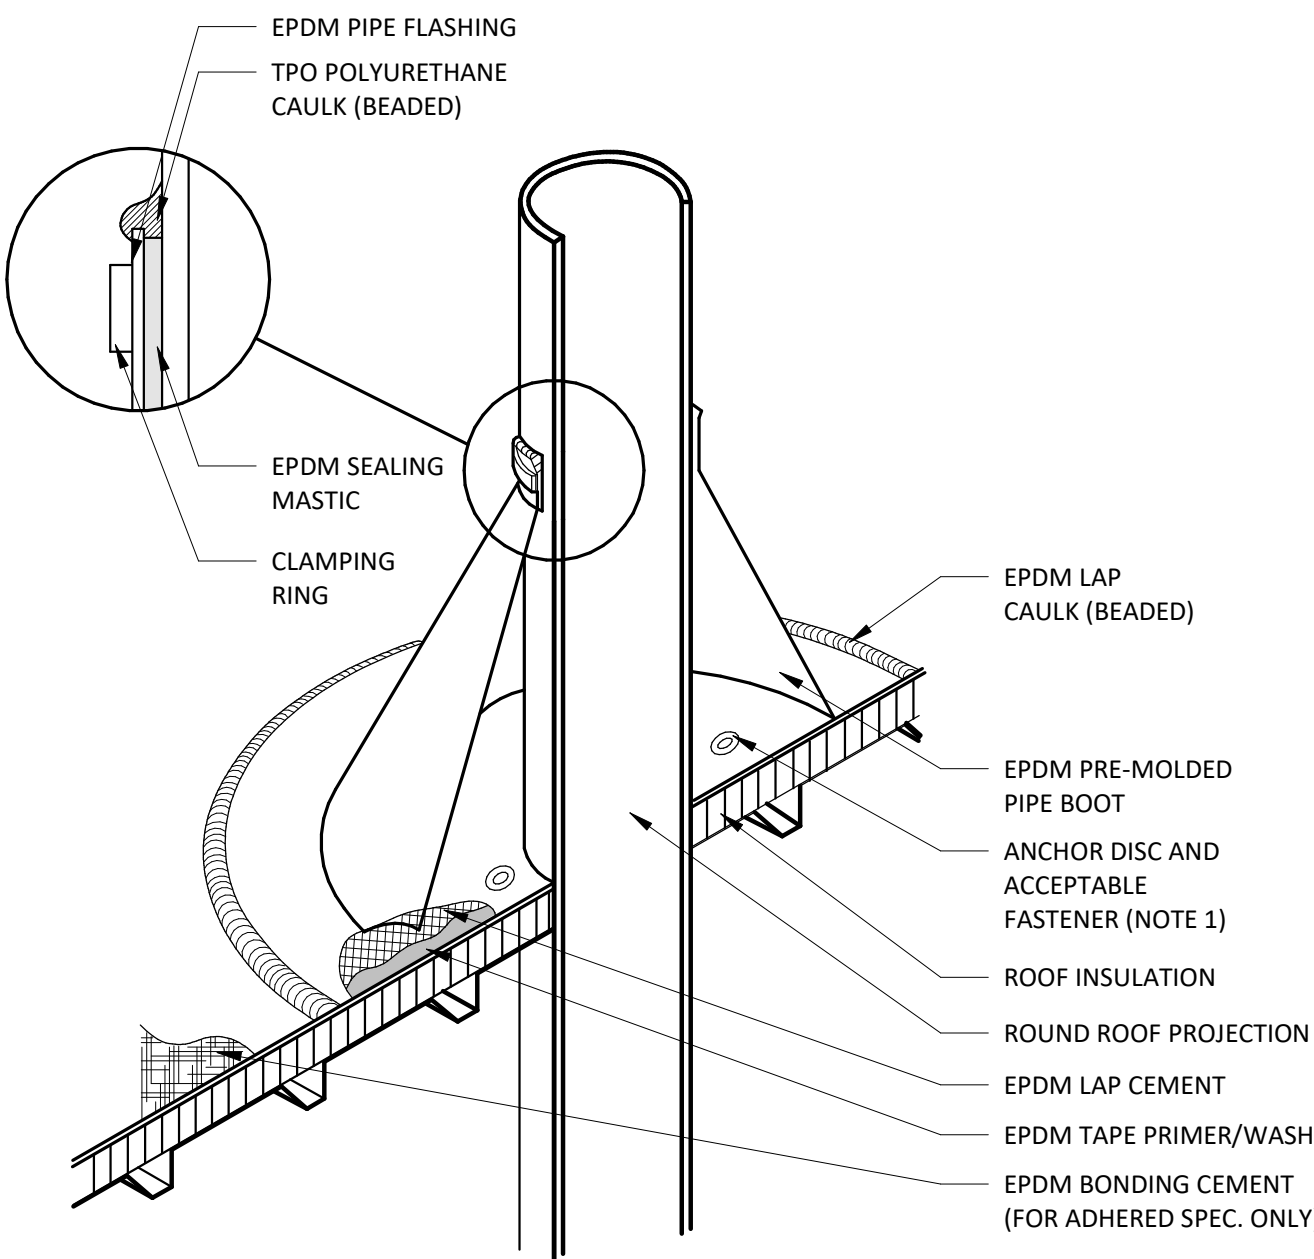


NOTE:

- WITH MECHANICALLY FASTENED OR BALLASTED SPECIFICATIONS, MEMBRANE MUST BE MECHANICALLY ATTACHED WITH 2" (50 mm) ANCHOR DISC AND ACCEPTABLE FASTENERS (MINIMUM OF 4 PER PIPE).
- DO NOT OVERLAP THE FLANGES FROM ADJACENT PIPE FLASHINGS.
- ANY SEAM UNDER BOOT FLANGE TO BE TREATED AS T-JOINT.
- BOTH SURFACES TO BE MATED MUST BE CLEANED WITH TAPE PRIMER/WASH. EPDM TAPE PRIMER/WASH MUST BE COMPLETELY DRY AND TACK FREE BEFORE APPLYING EPDM LAP CEMENT.

BOOT DETAIL

2
A140
1/2" = 1'-0"

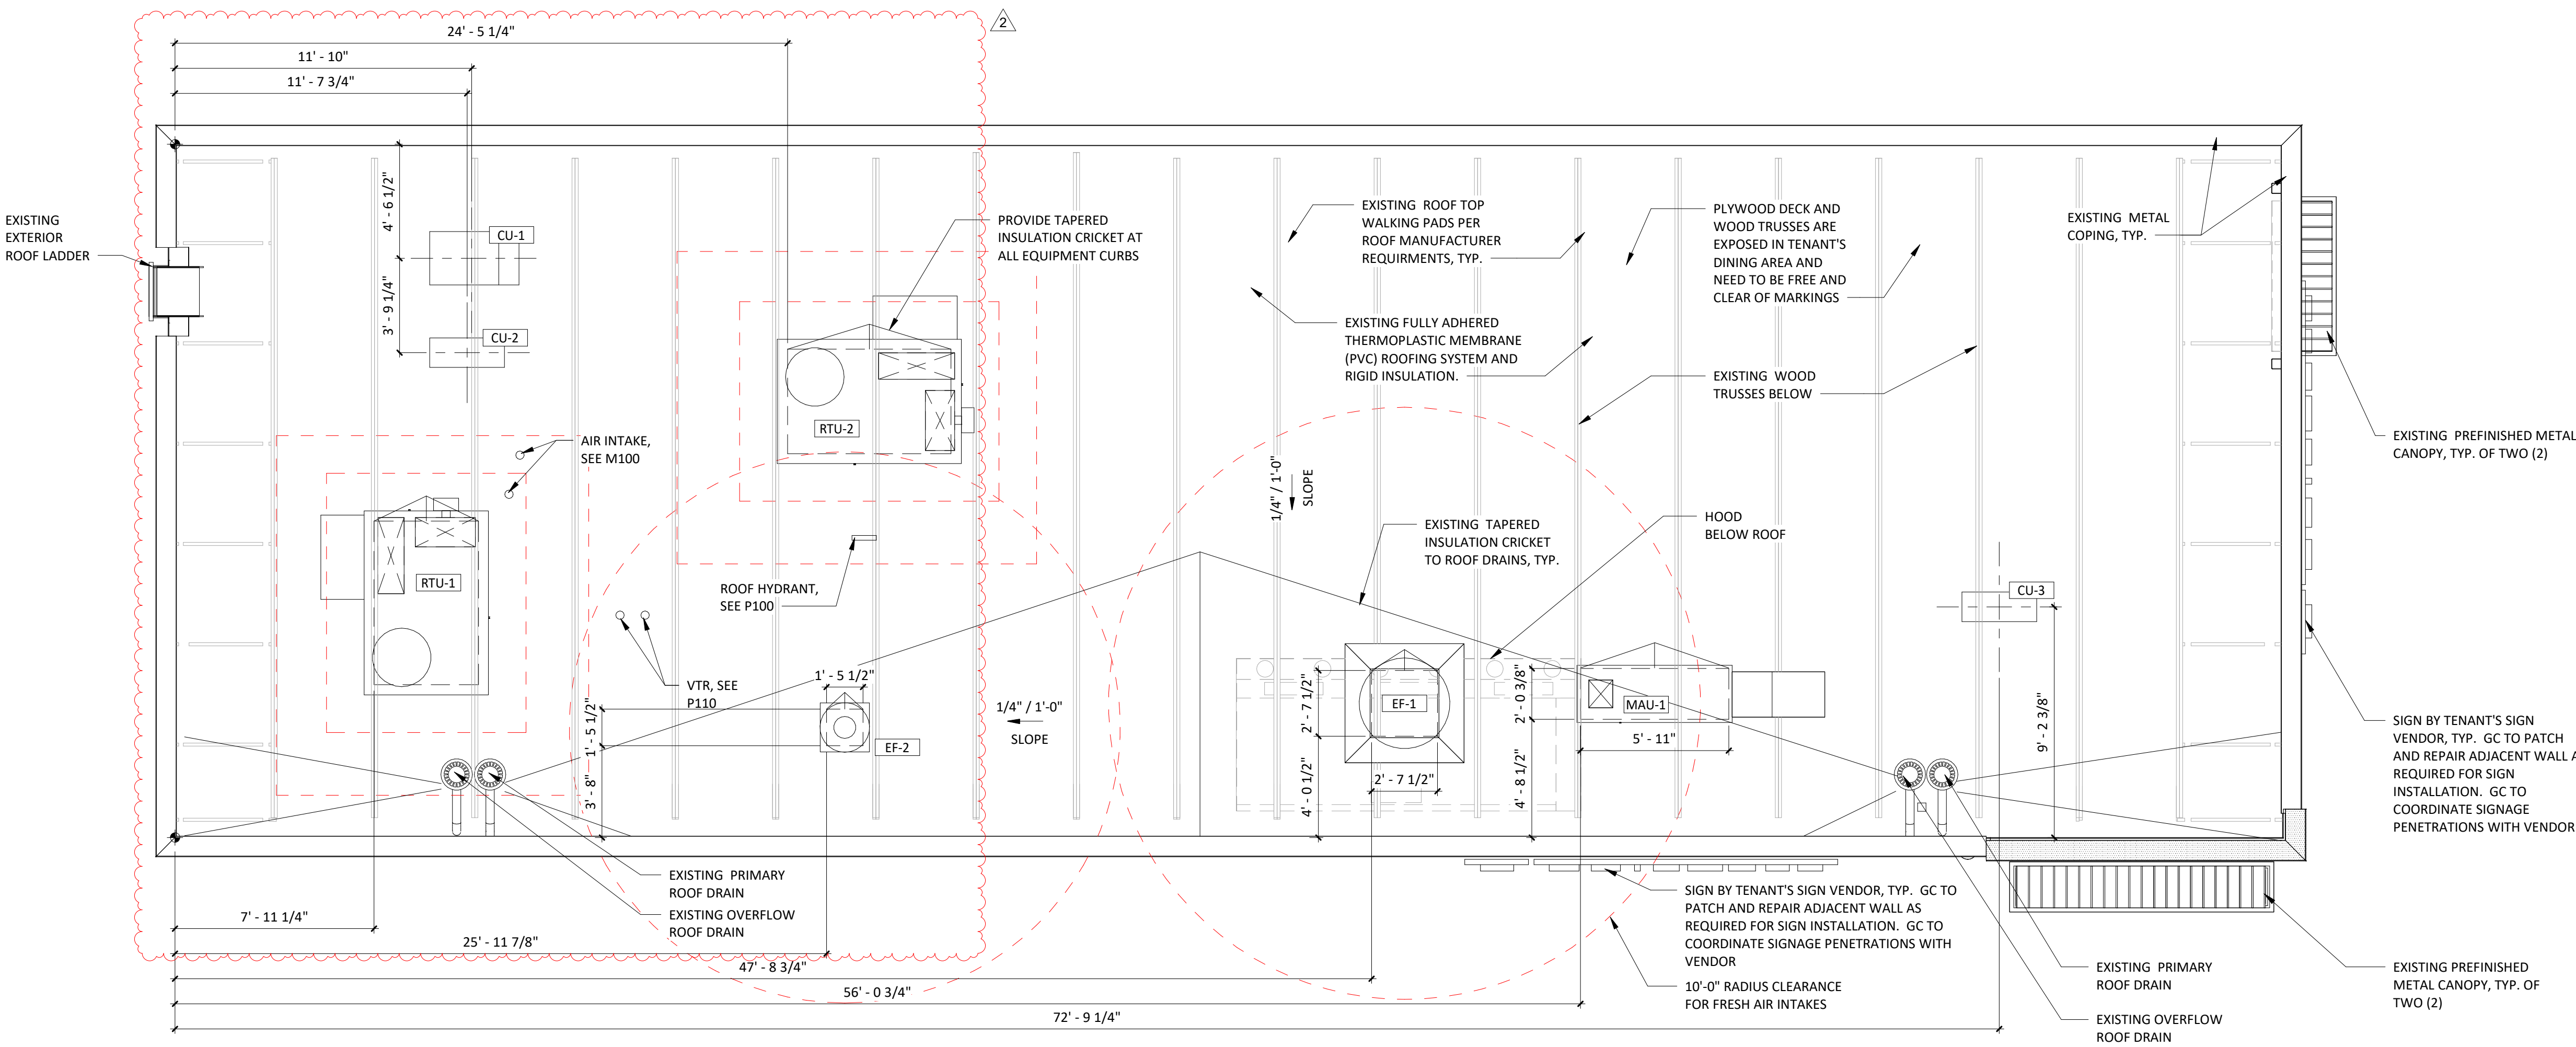

ROOF PLAN

1
A140
1/4" = 1'-0"

1.	ALL INTERIOR LIGHT FIXTURES AND LAMPS PROVIDED BY TENANT'S LIGHT/LAMP SUPPLIER.
2.	ALL INTERIOR LIGHT FIXTURES AND LAMPS INSTALLED BY GC. CAREFULLY REVIEW LIGHTING FIXTURE SCHEDULE ON SHEET E100.
3.	KITCHEN EXHAUST HOOD PROVIDED BY HS AND INSTALLED BY GC. GC TO COORDINATE PRESSURE TEST AND VIRO GUARD WITH ENVIRONMENTAL, INC.
4.	ANSUL BOB & FIRE SUPPRESSION SYSTEM PROVIDED BY AND INSTALLED BY HS. HOOD INTERLOCK BY GC. ELECTRICAL CONNECTION BY GC, RE. ELEC.
5.	MENU BOARD ASSEMBLY PROVIDED BY TMB, INSTALLED BY G.C.
6.	PROVIDE BLOCKING ABOVE MENU BOARD ASSEMBLY FOR INSTALLATION.
7.	REFER TO "09900 PAINTING - GENERAL" IN SPECIFICATIONS FOR FINISHES AT EXPOSED CEILING AREAS IN ADDITION TO NOTES LISTED ON THIS SHEET AND A120.
8.	UNISTRUT TO BE LEFT UNPAINTED. PROVIDE MATCHING CLOSER STRIPS AND END CAPS. CLOSER STRIP TO BE APPLIED TO THE UNDERSIDE OF THE UNISTRUT.
9.	ALL HEIGHTS ARE TO BOTTOM OF FIXTURE UNLESS NOTED OTHERWISE.
10.	LIGHT DETAILS ARE LOCATED ON SHEET A210. FIXTURE AND LAMP SPECIFICATIONS ARE LOCATED ON E100.
11.	ALL UNISTRUT SUPPORTING CEILING ELEMENTS AND/ OR DUCT WORK SHALL NOT CONTAIN ANY ELECTRICAL CONDUIT. ALL ELECTRICAL CONDUIT MUST RUN IN SEPARATE UNISTRUT.
12.	ALL UNISTRUT, CONDUIT, SPRINKLER & WATER LINES SHALL BE INSTALLED TIGHT TO THE BOTTOM OF THE DECK OR AS SHOWN IN DETAILS AND LEFT UNPAINTED
13.	ALL WATER LINES AND EXPOSED PVC SHALL BE INSTALLED IN TRUSS SPACE AND PAINTED VICTORIAN PEWTER.
14.	ALL DIMENSIONS ARE TO FACE OF FRAMING, OR CENTERLINE OF FIXTURE UNLESS NOTED OTHERWISE.
15.	SEE ELECTRICAL DRAWINGS FOR SHATTER RESISTANT LAMP LOCATIONS.
16.	ALL EMERGENCY FIXTURES, LIGHTS AND STROBES SHALL BE ALIGNED OR CENTERED ON WALLS.
17.	FULL CERAMIC TILE COURSEING SHALL TAKE PRECEDENT OVER ANY CEILING/HEADER DIMENSION INDICATED IN THE PLAN, REFER TO A120.
18.	ALL CONDUIT AND PIPE PENETRATIONS OF THE SERVING LINE SOFFIT ARE TO BE HELD TIGHT TO THE DECK. PLEASE CONSULT WITH THE CHIPOTLE CM SHOULD ANY CONFLICTS ARISE.
19.	BATT INSULATION TO BE INSTALLED ABOVE THE RESTROOM CEILING.
20.	ALL LAY-IN CEILING PENETRATIONS TO BE HELD TIGHT TO WALLS. REFER TO 4/A210 AND PLUMBING DRAWINGS FOR DETAILS.
21.	REFER TO STRUCTURAL DRAWINGS FOR HOOD SUSPENSION DETAILS.
22.	ALL EXTERIOR BUILDING MOUNTED AND PATIO LIGHT FIXTURES AND LAMPS PROVIDED BY TENANT'S LIGHT/LAMP SUPPLIER, U.N.O.
23.	ALL EXTERIOR PARKING LOT LIGHT FIXTURES AND LAMPS PROVIDED BY AND INSTALLED BY G.C. CAREFULLY REVIEW LIGHTING FIXTURE SCHEDULE ON SHEET E100.
24.	ALL EXTERIOR BUILDING MOUNTED AND PATIO LIGHT FIXTURES AND LAMPS INSTALLED BY G.C. CAREFULLY REVIEW LIGHTING FIXTURE SCHEDULE ON SHEET E100.
25.	SECURITY CAMERA LOCATIONS ARE ONLY APPROXIMATE LOCATIONS. FOR GUIDANCE ON THE SPECIFIC LOCATION/ORIENTATION OF THESE CAMERAS, REFER TO THE ENVYSION INSTALLATION GUIDE
26.	REFER TO A120 FOR FINISH SCHEDULE

DESCRIPTION	QTY	SUPPLIED BY	INSTALLED BY	UTILITIES			REMARKS
				ELEC	GAS	SEWER	
SECURITY MONITOR	1	\$55	\$55	●			GC RESPONSIBLE FOR COORDINATING SEQUENCING OF PREWIRING WITH COMPLETION OF INTERIOR FINISHES (GYP. BD. FINISHES)
SECURITY ALARM - MOTION DETECTORS	1	T.B.D.	T.B.D.	●			
72 HR SECURITY DVR	1	\$55	\$55	●			INSTALL AT 9'-6" U.N.O.
CLOSED CIRCUIT T.V. CAMERA - OUTDOOR	2	\$55	\$55	●			
CLOSED CIRCUIT T.V. CAMERA - INDOOR	6	\$55	\$55	●			

SEE ELECTRICAL DRAWINGS FOR CONDUIT REQUIREMENTS, METAL CLAD CABLE AND FLEXIBLE METAL CONDUIT SHALL NOT BE INSTALLED IN AREAS EXPOSED TO VIEW UNLESS SPECIFICALLY NOTED OTHERWISE.					
SPEAKER SCHEDULE					
ITEM #	QTY	DESCRIPTION	COLOR/FINISH	MOUNT	REMARKS
SP1	4	DINING ROOM SPEAKER	BLACK	SUSPENDED	REFER TO A201 & E110 FOR DETAILS



ITEM #	QTY	MOUNT	DESCRIPTION	REMARKS
A1	11	LAY-IN	2x2 LENSED TROFFER	SEE SHEET E100
B1	8	CEILING	RECESSED 6IN CAN LIGHT	SEE SHEET E100
B2	24	CEILING	RECESSED 6IN CAN LIGHT	SEE SHEET E100
B3	2	CEILING	M4.0 - RECESSED 6IN CAN LIGHT (BLACK)	SEE SHEET E100
C0	4	SURFACE	LOW PROFILE LED 1FT	SEE SHEET E100
C1	1	SURFACE	LOW PROFILE LED 2FT	SEE SHEET E100
C2	20	SURFACE	LOW PROFILE LED 3FT	SEE SHEET E100
C3	4	SURFACE	LOW PROFILE LED 4FT	SEE SHEET E100
C4	1	SURFACE	LOW PROFILE LED 5FT	SEE SHEET E100
E1	6	VARIOUS	EMERGENCY LIGHT - DUAL HEAD (EXISTING)	SEE SHEET E100
E2	4	VARIOUS	EMERGENCY LIGHT - SINGLE HEAD (EXISTING)	SEE SHEET E100
E4	4	VARIOUS	WHITE EXIT LIGHT - STANDARD RED LETTERS (EXISTING)	SEE SHEET E100
E7	7	VARIOUS	EMERGENCY LIGHT - DUAL HEAD	SEE SHEET E100
H1	8	SURFACE	VAPOR PROOF HOOD LIGHT	SEE SHEET E100
J4	2	PENDANT	M4.0 - PENDANT LIGHT	SEE SHEET E100
P6	1	PENDANT	M4.0 - MULTI-PENDANT LIGHT	SEE SHEET E100 & A701
T1	9	TRACK	TRACK LIGHTING HEAD	SEE SHEET E100
T-6	3	SUSPENDED	M4.0 - TRACK 6"	SEE SHEET E100
X1	1	EXTERIOR CAN	EXTERIOR RECESSED CAN (EXISTING)	SEE SHEET E100
X6.1	3	WALL	WALL PACK (EXISTING)	SEE SHEET E100
X9	2	SURFACE	LED CHANNEL LIGHT (EXISTING)	SEE SHEET E100




REFER TO A201 FOR GENERAL NOTES

FOR
CONSTRUCTION

COPYRIGHT 2023
THIS DRAWING IS AN INSTRUMENT OF SERVICE
AND AS SUCH REMAINS THE PROPERTY OF
CHIPOTLE MEXICAN GRILL, INC.. PERMISSION FOR
USE OF THIS DOCUMENT IS LIMITED AND CAN BE
EXTENDED ONLY BY WRITTEN AGREEMENT WITH
CHIPOTLE MEXICAN GRILL, INC..



STORE NO.: 4870
WALNUT HILLS
1202 E MCMILLAN STREET
CINCINNATI, OH 45206

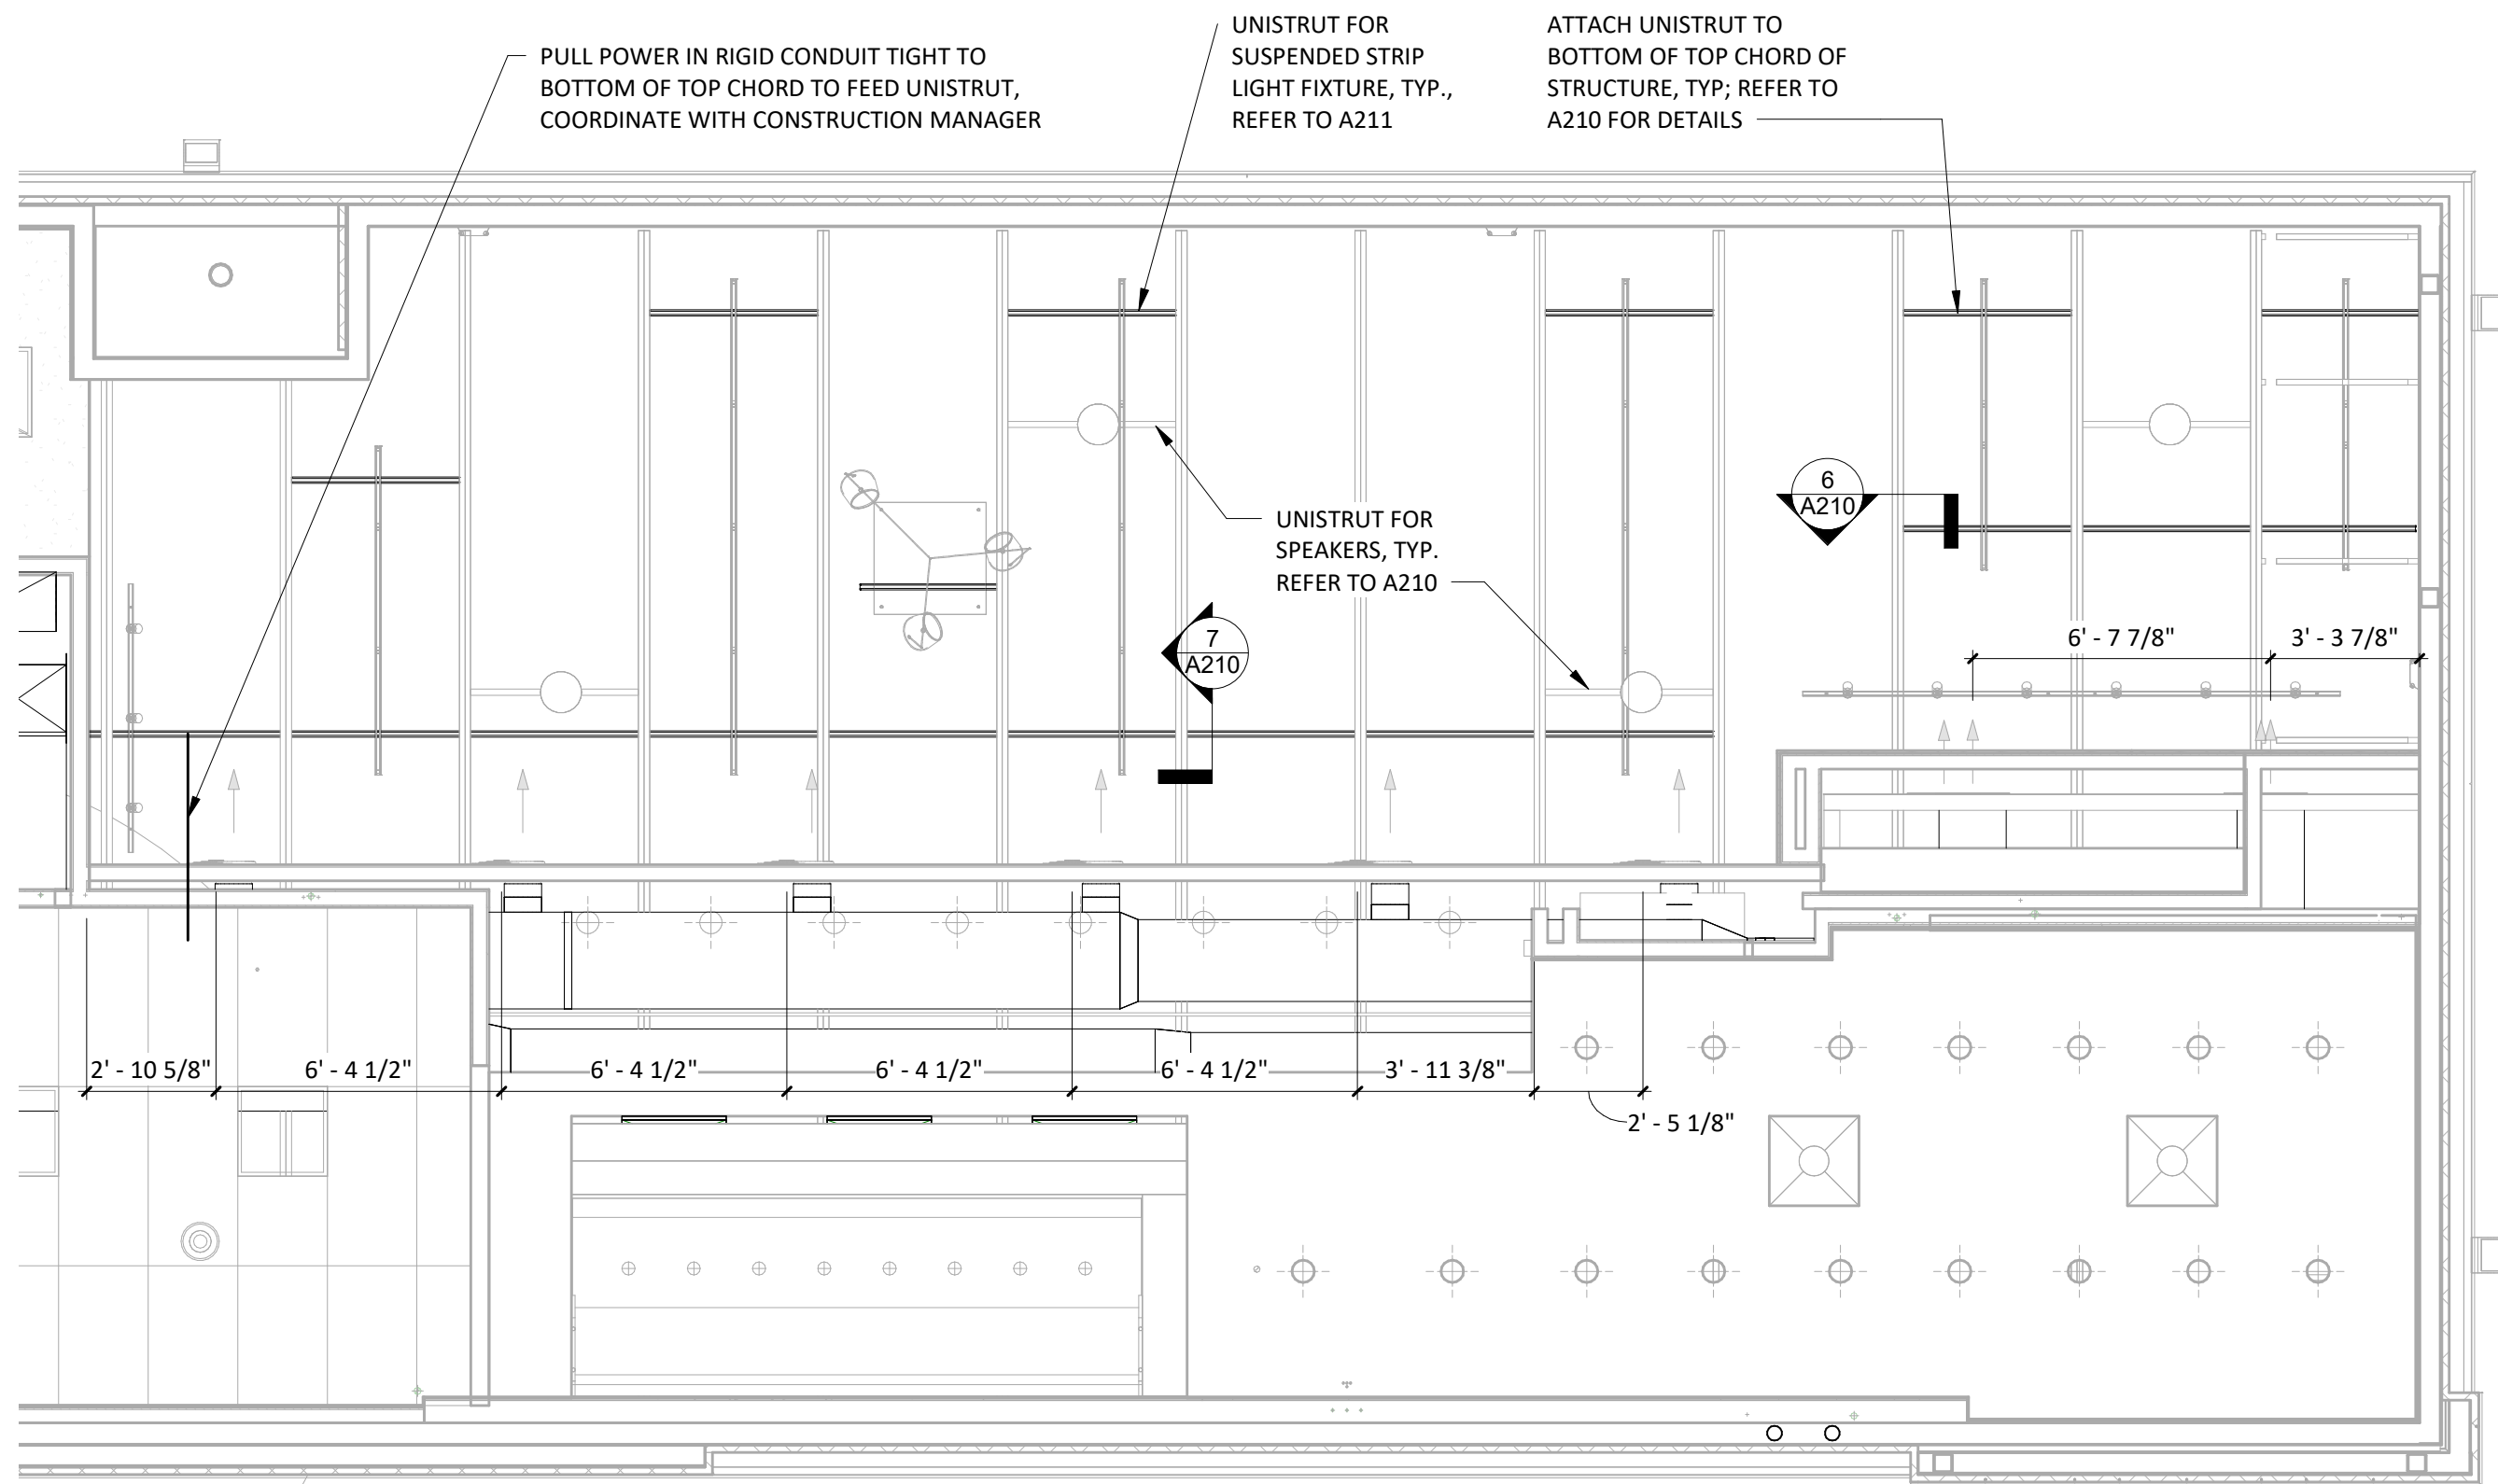

 **UNISTRUT AND DUCTWORK LAYOUT**
1/4" = 1'-0"

Issue Record:	
11/03/23	PERMIT SET
05/08/24	CONSTRUCTION SET

Revisions:	

Drawn:	Checked:
JTH, PH	TC

Project No.
CMG1144

Contents:
**REFLECTED CEILING
& UNISTRUT PLAN**

GENERAL NOTES

1. REFER TO EXTERIOR ELEVATIONS THIS SHEET FOR EXTERIOR SIGNAGE LOCATIONS, SIZES & DESCRIPTIONS.
2. EXTERIOR SIGNAGE PROVIDED BY TSV AND INSTALLED BY TSV. GC TO MAKE FINAL CONNECTION.

Consultant:

R/A

RedArchitecture

589 W. NATIONWIDE BLVD. SUITE B
COLUMBUS, OHIO 43215 (614) 487-8770

FOR
CONSTRUCTION

COPYRIGHT 2023
THIS DRAWING IS AN INSTRUMENT OF SERVICE
AND AS SUCH REMAINS THE PROPERTY OF
CHIPOTLE MEXICAN GRILL, INC.. PERMISSION FOR
USE OF THIS DOCUMENT IS LIMITED AND CAN BE
EXTENDED ONLY BY WRITTEN AGREEMENT WITH
CHIPOTLE MEXICAN GRILL, INC..



CHIPOTLE MEXICAN GRILL, INC.
PO BOX 182566
COLUMBUS, OH 43218-2566
TELEPHONE: 614.318.2400
INTERNET: WWW.CHIPOTLE.COM

STORE NO.: 4870
WALNUT HILLS
1202 E MCMILLAN STREET
CINCINNATI, OH 45206

Issue Record:

11/03/23 PERMIT SET
05/08/24 CONSTRUCTION SET

Revisions:

Drawn:

JTH,
PH

Checked:

TC


Project No.

CMG1144


Contents:

EXTERIOR
ELEVATIONS


A301

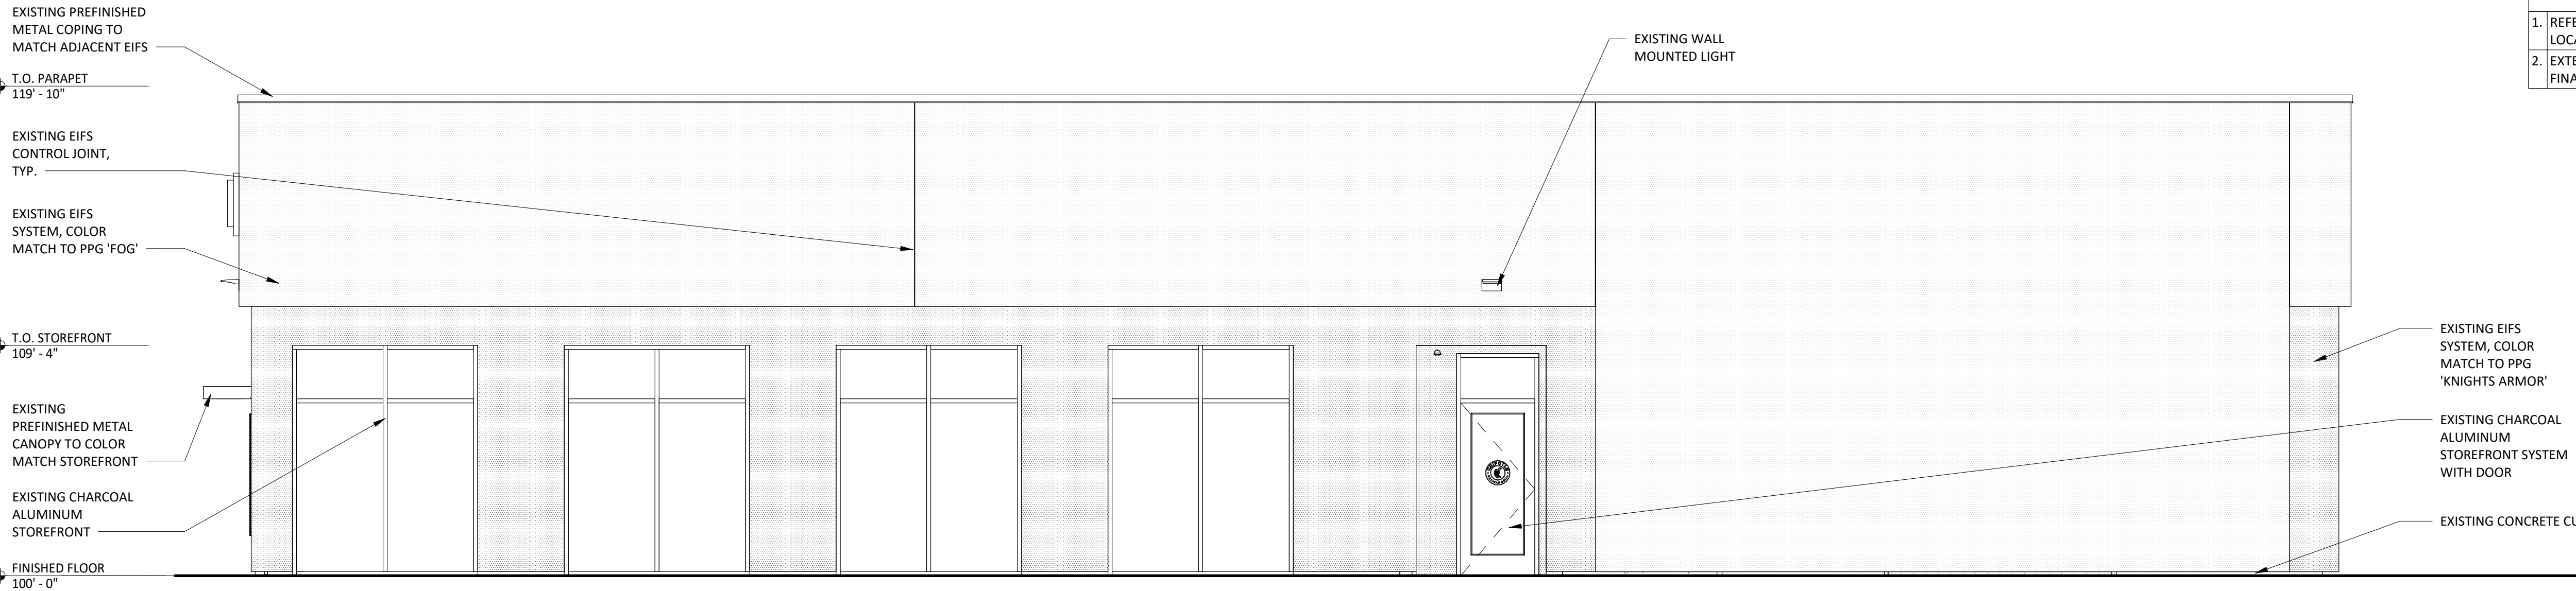


4
A301
EXT ELEV - EAST
1/4" = 1'-0"

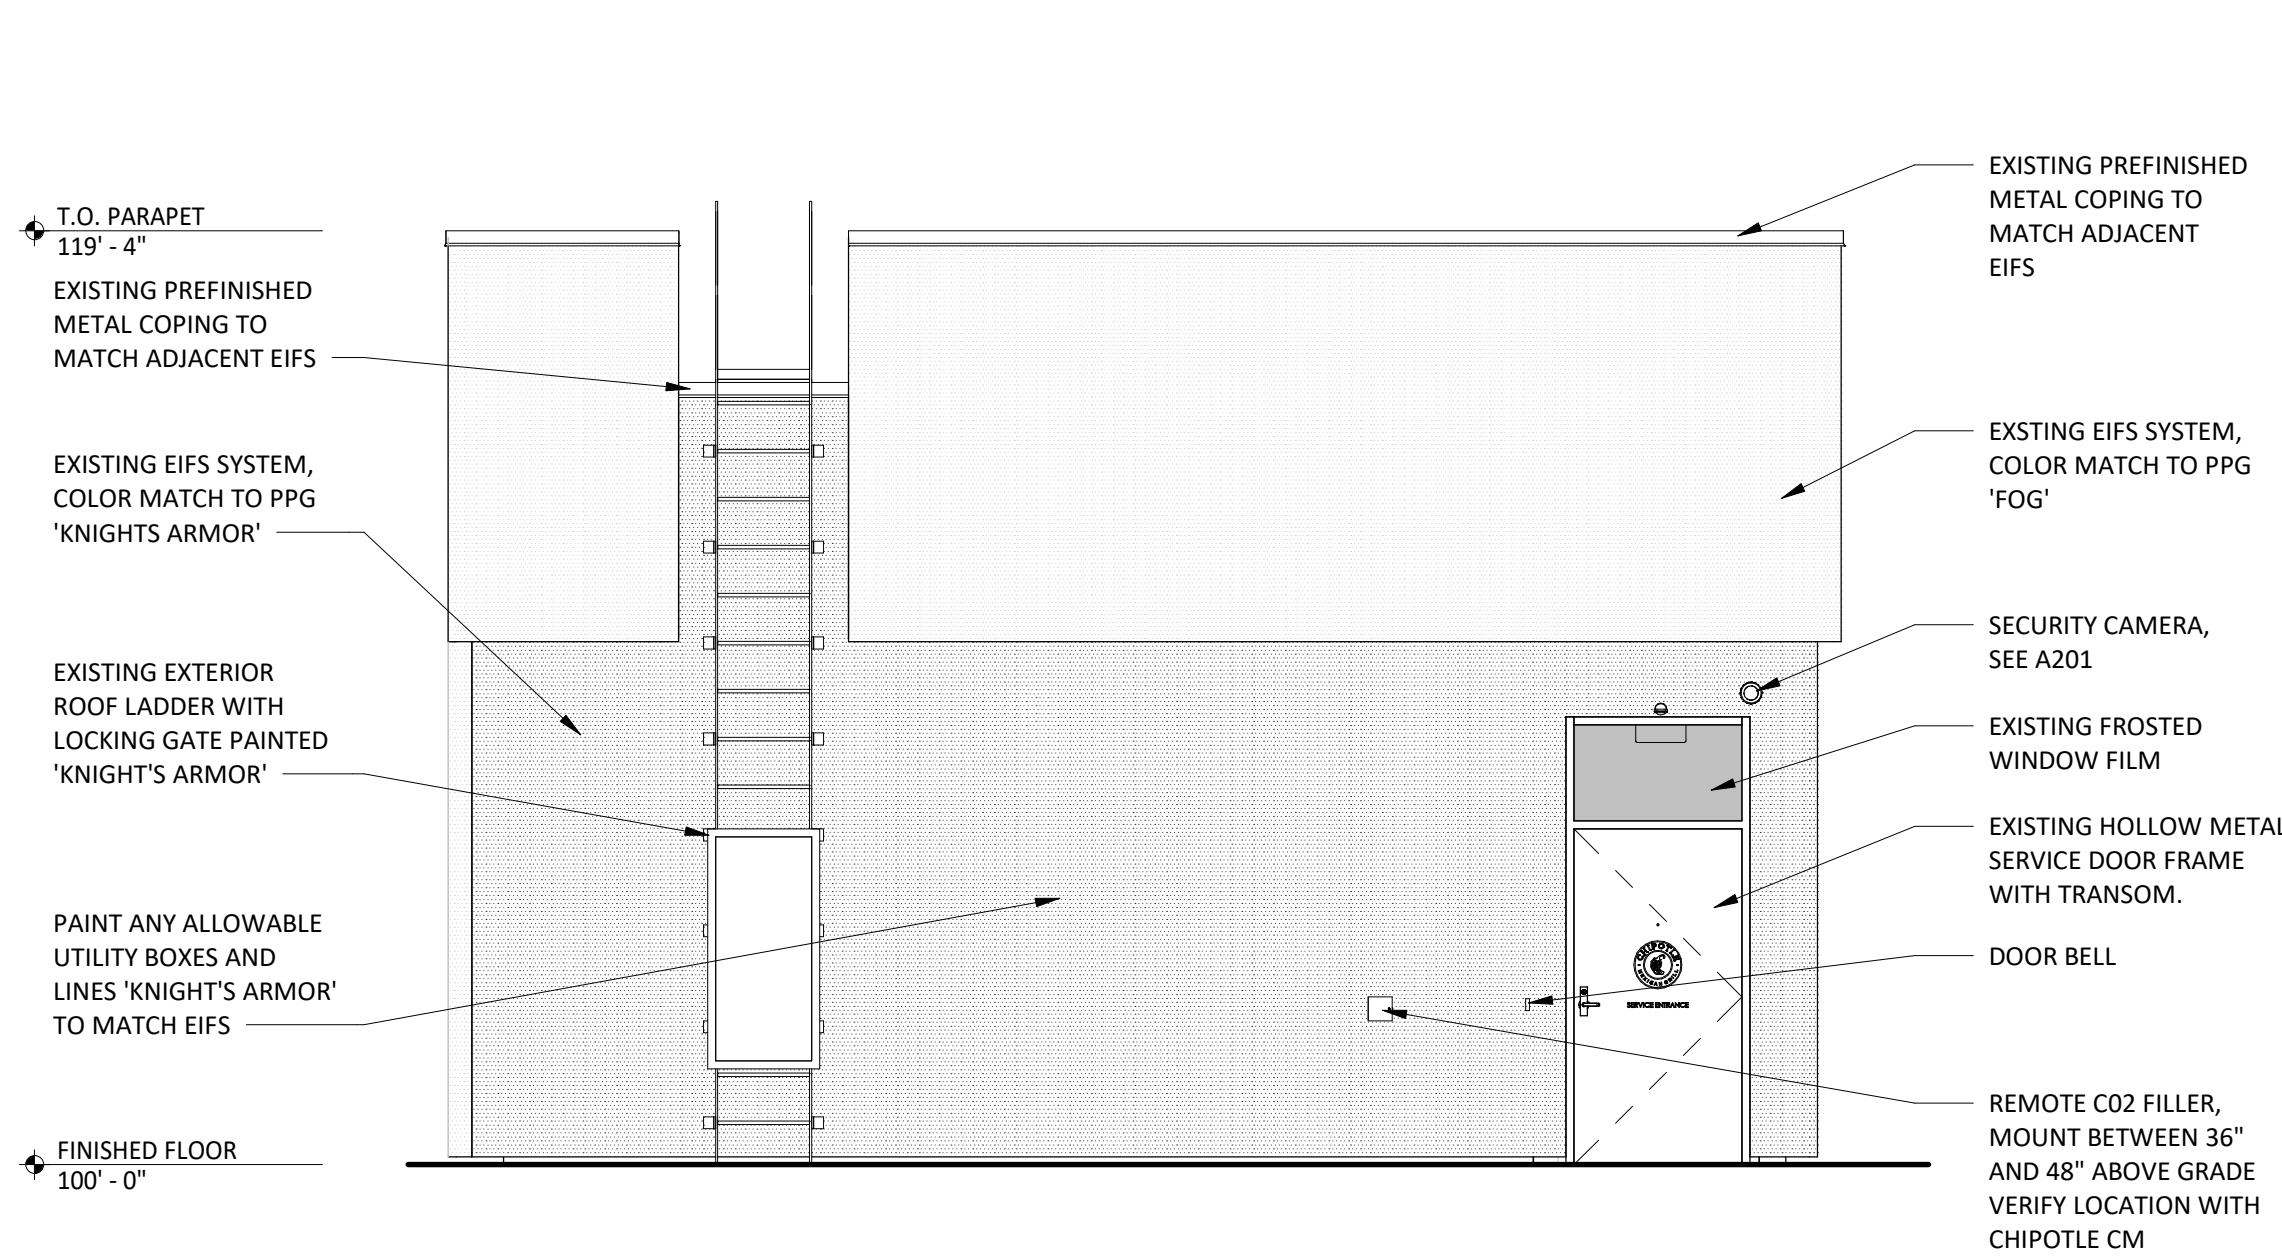

3
A301
EXT ELEV - NORTH
1/4" = 1'-0"



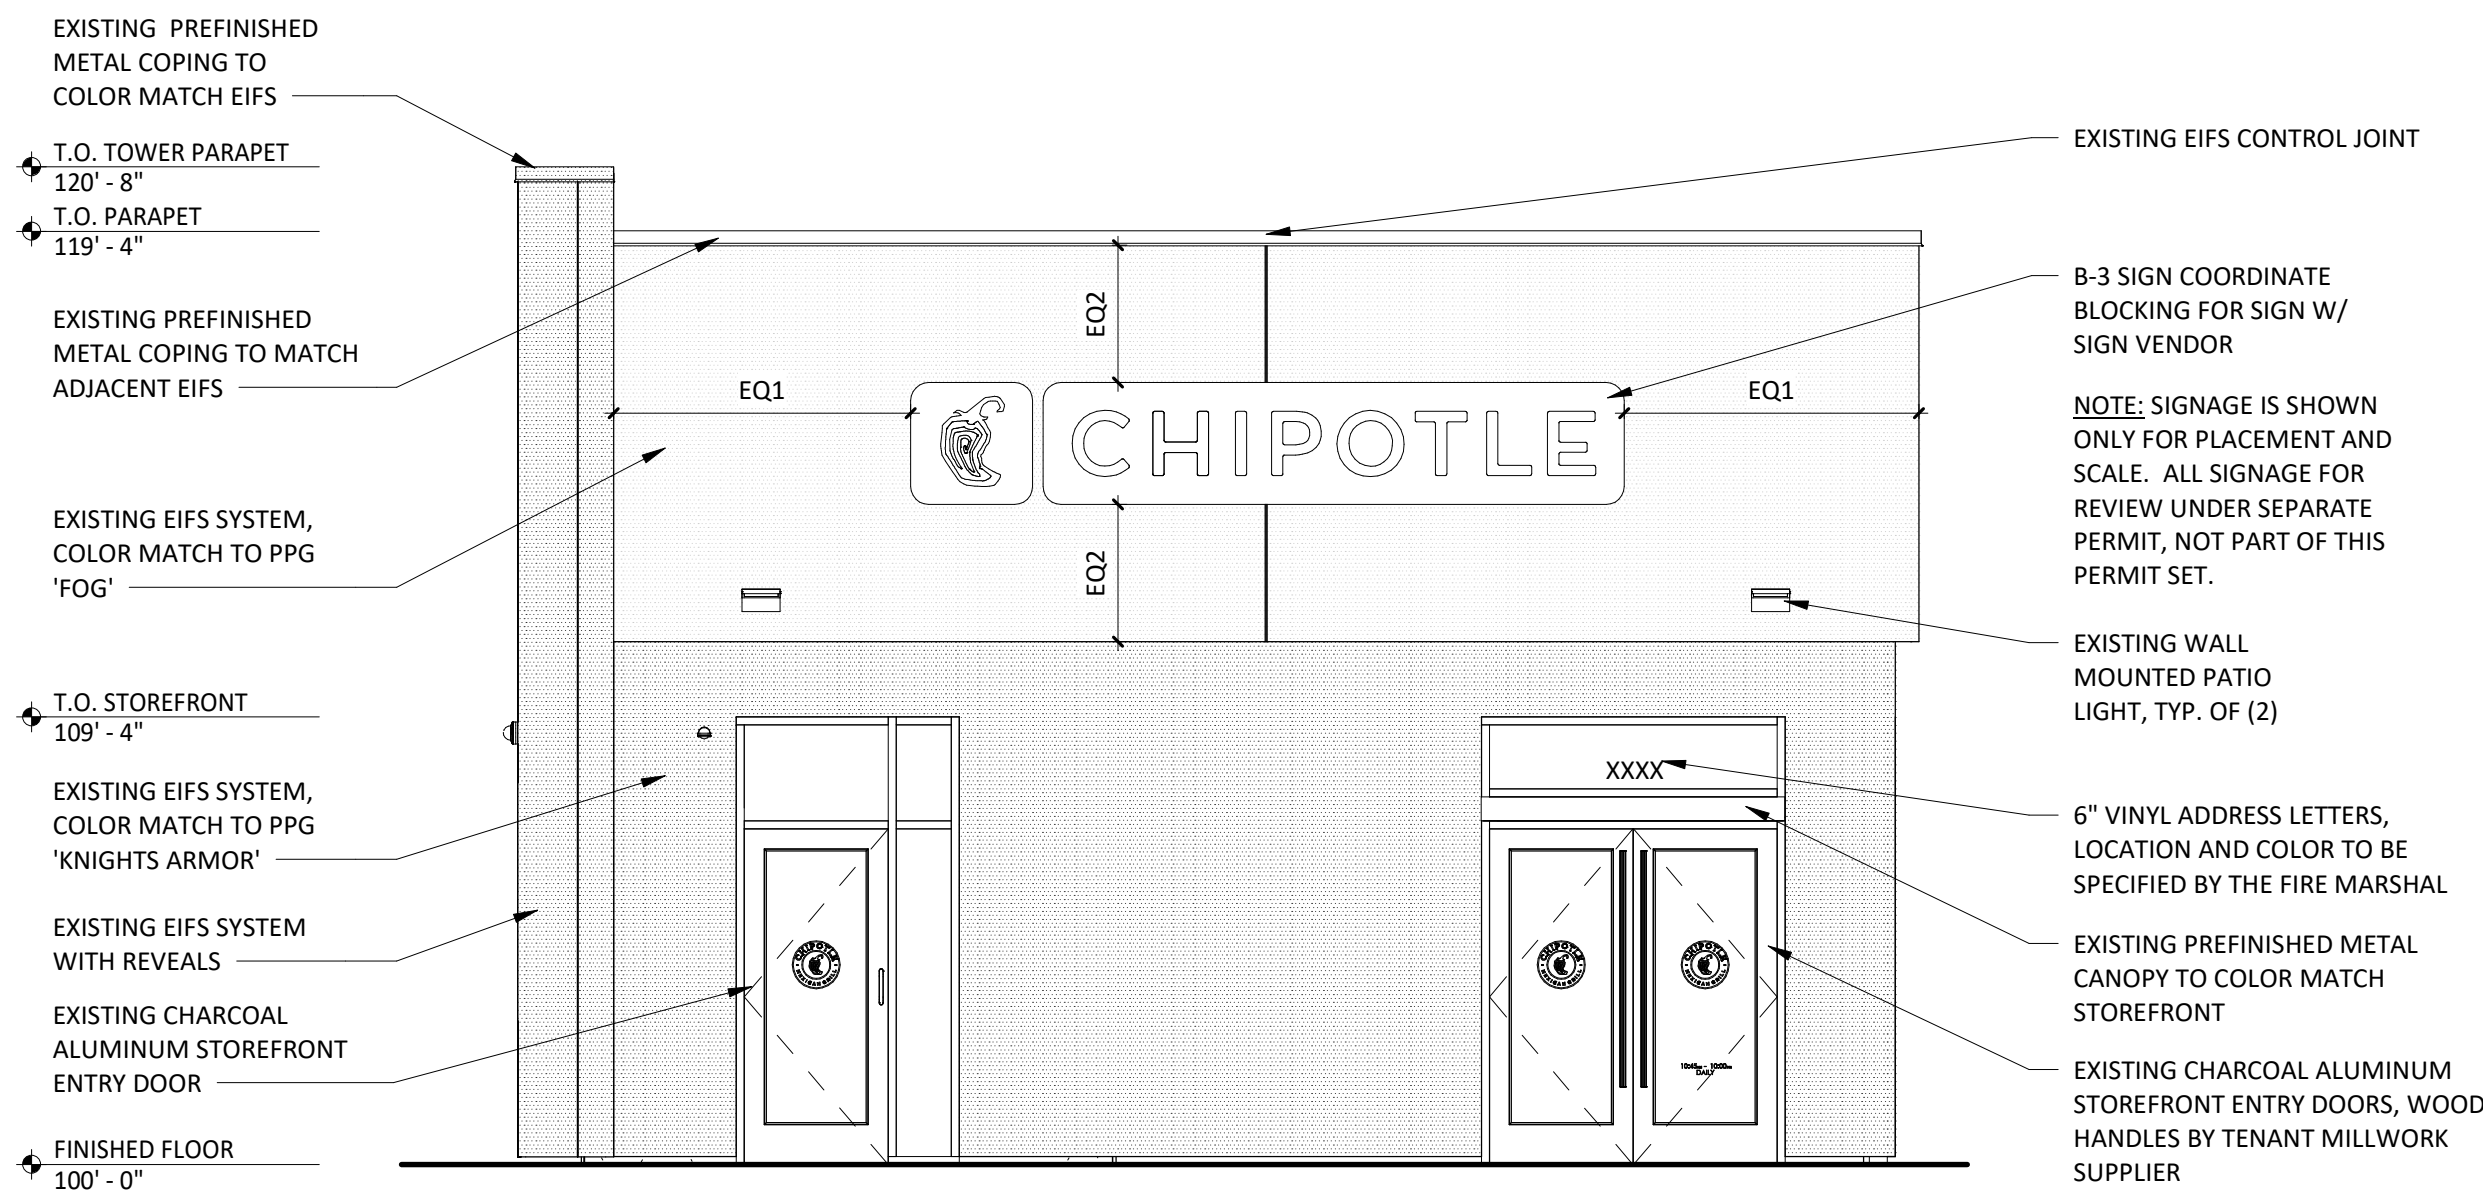


2
A301
EXT ELEV - SOUTH
1/4" = 1'-0"

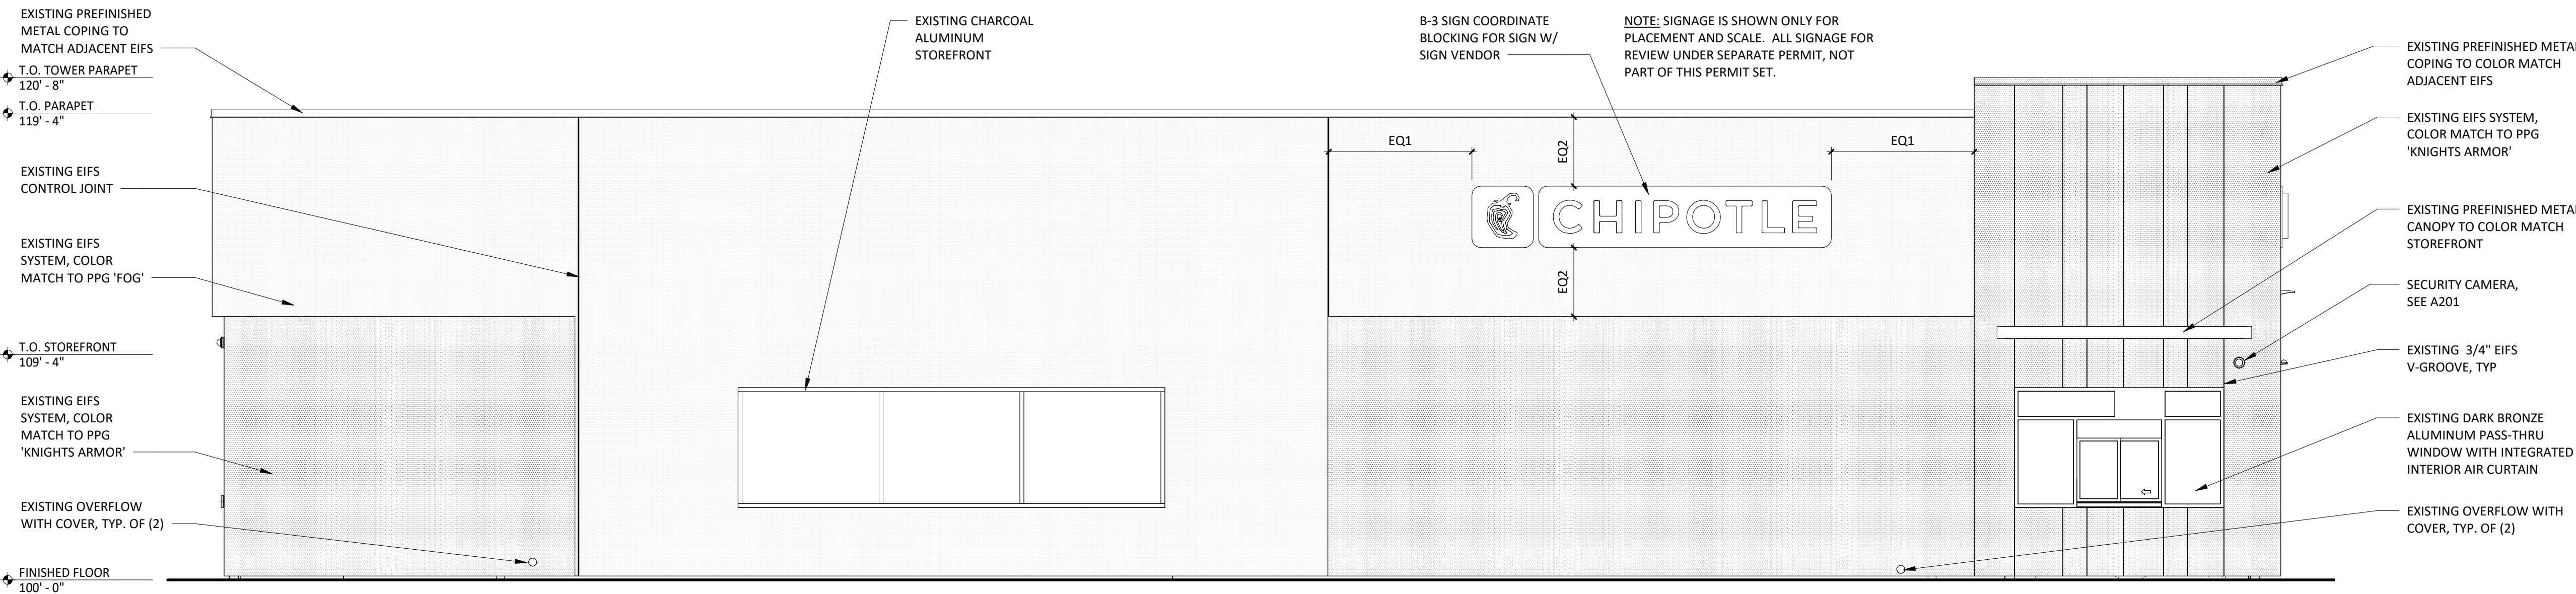

1
A301
EXT ELEV - WEST
1/4" = 1'-0"



   

DOOR SCHEDULE																REMARK NOTES		TYPICAL EXTERIOR DOOR TYPES	
TAG	ROOM	DOOR STATUS *	FRAME STATUS	DOOR DESCRIPTION	DOOR WIDTH	HEIGHT	THICKNESS	DOOR DOOR TYPE	DOOR FINISH	FRAME FRAME TYPE	MATERIAL	STILE	HARDWARE SET	HARDWARE STATUS*	FIRE RATING	REMARKS	1.	2.	
1	MAIN ENTRY	EXISTING	EXISTING	DOUBLE STOREFRONT (WIDE STILE, WOOD PULL, PANIC)	6' - 0"	7' - 0"	0' - 1 3/4"	A	SEE A301	STOREFRONT	ALUM	WIDE (5")	1B	EXISTING			1,2,4,5	1. DOORS WITH REMARK #1 TO BE KEYED THE SAME	
2	POS	EXISTING	EXISTING	SINGLE STOREFRONT (WIDE STILE, NON-OFFSET, PANIC)	3' - 0"	7' - 0"	0' - 1 3/4"	A	SEE A301	STOREFRONT	ALUM	WIDE (5")	2A	EXISTING			1,3,4,5	2. EXIT INDICATOR ARRIVES WITH SIGNS STATING "THIS DOOR TO REMAIN UNLOCKED DURING BUSINESS HOURS" AND "THIS DOOR TO REMAIN UNLOCKED WHEN THE BUILDING IS OCCUPIED". VERIFY REQUIRED SIGN WORDING WITH LOCAL JURISDICTION PRIOR TO INSTALLATION. ONE SIGN IS TO BE PLACED IN A VISIBLE LOCATION ABOVE THE DOORS.	
3	ORDERING	EXISTING	EXISTING	SINGLE STOREFRONT (WIDE STILE, EGRESS ONLY, PANIC)	3' - 0"	7' - 0"	0' - 1 3/4"	A	SEE A301	STOREFRONT	ALUM	WIDE (5")	2B	EXISTING			1,3,4,5	3. THERE IS TO BE NO EXTERIOR HOLE OR CYLINDER	
4	KITCHEN	EXISTING	EXISTING	HM REAR KITCHEN (STANDARD)	3' - 6"	7' - 0"	0' - 1 3/4"	D	D1/D2 (SEE A120)	2	H.M.	-	3	EXISTING			1,4,6	4. USE NON-SHRINK STRUCTURAL GROUT BED UNDER THRESHOLD	
5	UNISEX 2	NEW	NEW	UNISEX 2 RESTROOM (SINGLE-OCCUPANT, PUSH LOCK)	3' - 0"	7' - 0"	0' - 1 3/4"	B	D1 (SEE A120)	1	H.M.	-	5A	NEW				5. BLACK DOOR SWEEP TO BE USED WITH CHARCOAL, BLACK OR BRONZE STOREFRONT. LIGHT GRAY DOOR SWEEP TO BE USED WITH CLEAR ANODIZED ALUMINUM STOREFRONT	
6	UNISEX 1	NEW	NEW	UNISEX 1 RESTROOM (SINGLE-OCCUPANT, PUSH LOCK)	3' - 0"	7' - 0"	0' - 1 3/4"	B	D1 (SEE A120)	1	H.M.	-	6A	NEW				6. REAR KITCHEN DOOR TO BE PAINTED 'BLACK' ON INTERIOR AND 'KNIGHT'S ARMOR' ON EXTERIOR U.N.O.	
7	OFFICE	NEW	NEW	MANAGER'S OFFICE	3' - 0"	7' - 0"	0' - 1 3/4"	C	D1 (SEE A120)	1	H.M.	-	4	NEW					
																*IF STATUS IS "EXISTING" G.C TO DETERMINE CONDITION OF EXISTING HADWARE. IF HARDWARE IS IN POOR CONDITION, PROVIDE HARDWARE IN HARDWARE SCHEDULE. CONFIRM REPLACEMENT WITH CHIPOTLE CM.			
HARDWARE SETS																			
SET 1 - MAIN ENTRY - PAIR - WOOD PULL/PUSH																			
(2)	HINGE		HAGER, MODEL 780-224HD-83"-CLR																
(2)	MORTISE CYLINDER		SCHLAGE, MODEL 80-103, BRUSHED CHROME; C.O. CYLINDER AT 34" MIN. FROM BOTTOM OF DOOR																
(2)	TEMP CORE		SCHLAGE, MODEL 80-035 INTERCHANGEABLE CORE, (BRUSHED CHROME)																
(2)	PUSH HARDWARE		1 1/2" DIAMETER WOOD PUSH, VARIES HIGH - PROVIDED BY MILLWORK SUPPLIER. MOUNT TOP OF PULLS FLUSH WITH TOP OF GLAZING STOP IN DOOR, RE: SHOP DRAWINGS																
(2)	PULL HARDWARE		1 1/2" DIAMETER WOOD PULL, VARIES HIGH - PROVIDED BY MILLWORK SUPPLIER. MOUNT TOP OF PULLS FLUSH WITH TOP OF GLAZING STOP IN DOOR, RE: SHOP DRAWINGS																
(1)	DEADBOLT		ADAMS RITE, MODEL MS1850S-310-628																
(1)	EXIT INDICATOR		ADAMS RITE, MODEL 4089-00-130																
(1)	HEADER BOLT		ADAMS RITE, MODEL 4016-30-01																
(1)	THRESHOLD BOLT		ADAMS RITE, MODEL 4015-18-18																
(2)	CLOSER		DORMA, MODEL 8916-AF89P-689 (TOP JAMB), (ALUMINUM)																
(2)	DOOR STOP		IVES, MODEL FS18S (ALUMINUM)																
(2)	OVERHEAD STOP		GLYNN-JOHNSON, MODEL 454S-SP28 (ALUMINUM)																
(2)	CLOSER BACK PLATE		DORMA, MODEL BP89, ALUMINUM																
(1)	THRESHOLD		REESE, MODEL S424A-72 (SIZE 72")																
(2)	SMOKE SEAL		REESE, MODEL 797B-21																
(2)	DOOR SWEEP		PEMKO, MODEL SFSC-200-36 (36" DOOR),OWNER FURNISHED																
SET 2A - ENTRY - SINGLE - NON-OFFSET - PANIC HARDWARE																			
(1)	HINGE		HAGER, MODEL 780-224HD-83"-CLR																
(1)	PUSH HARDWARE		ADAMS RITE, MODEL 8801-36-628 (ALUMINUM FINISH, 36" DOOR); C.O. EXIT DEVICE AT 38" FROM BOTTOM OF DOOR																
(1)	PULL HARDWARE		HAGER, MODEL 4G US32D (8" CTC), CENTER ON DOOR STILE																
(1)	CLOSER		DORMA, MODEL 8916-AF89P-689 (TOP JAMB), (ALUMINUM)																
(1)	CLOSER BACK PLATE		DORMA, MODEL BP89, ALUMINUM																
(1)	OVERHEAD STOP		GLYNN-JOHNSON, MODEL 454S-US32D (ALUMINUM)																
(1)	THRESHOLD		REESE, MODEL S424A-36 (SIZE 36")																
(1)	SMOKE SEAL		REESE, MODEL 797B-21																
(1)	DOOR SWEEP		PEMKO, MODEL SFSC-200-36 (36" DOOR), OWNER FURNISHED																
(1)	DOOR STOP		IVES, MODEL FS18S (ALUMINUM)																
SET 2B - ENTRY - SINGLE - EGRESS ONLY - PANIC HARDWARE																			
(1)	HINGE		HAGER, MODEL 780-224HD-83"-CLR																
(1)	PUSH HARDWARE		ADAMS RITE, MODEL 8801-36-628 (ALUMINUM FINISH, 36" DOOR); C.O. EXIT DEVICE AT 38" FROM BOTTOM OF DOOR																
(1)	CLOSER		DORMA, MODEL 8916-AF89P-689 (TOP JAMB), (ALUMINUM)																
(1)	CLOSER BACK PLATE		DORMA, MODEL BP89, ALUMINUM																
(1)	OVERHEAD STOP		GLYNN-JOHNSON, MODEL 454S-US32D (ALUMINUM)																
(1)	THRESHOLD		REESE, MODEL S424A-36 (SIZE 36")																
(1)	SMOKE SEAL		REESE, MODEL 797B-21																
(1)	DOOR SWEEP		PEMKO, MODEL SFSC-200-36 (36" DOOR), OWNER FURNISHED																
(1)	DOOR STOP		IVES, MODEL FS18S (ALUMINUM)																
SET 3 - REAR EXIT - SINGLE																			
(1)	HINGE		HAGER, MODEL 780-224HD-83"-CLR																
(1)	PUSH HARDWARE		FALCON, MODEL 25-R-EQ-4"-US28 (SIZE 42")																
(1)	PULL HARDWARE		FALCON, MODEL S10L-DANE-LHR-US26D, ALUMINUM (EXTERIOR SIDE)																
(1)	RIM CYLINDER		GLS, MODEL RCIC-7-LZ-626																
(1)	TEMP CORE		SCHLAGE, MODEL 80-035 INTERCHANGEABLE CORE (FINISH: BRUSHED CHROME)																
(1)	CLOSER		DORMA, MODEL 8916-AF89P-689 (TOP JAMB), ALUMINUM																
(1)	CLOSER BACK PLATE		DORMA, MODEL BP89, ALUMINUM																
(1)	THRESHOLD		REESE, MODEL S239A-42, (SIZE 42")																
(1)	WEATHERSTRIP		REESE, MODEL D575C-4070																
(1)	DOOR SWEEP		PEMKO, MODEL SFSC-200-42 (42" DOOR) (BLACK) OWNER FURNISHED																
(1)	DOOR VIEWER		IVES, MODEL U698826D, C.O. VIEWER AT 60" FROM BOTTOM OF DOOR																
(1)	EXIT ALARM		TRINE, MODEL 206-3																
(1)	DOOR SILENCERS		IVES, MODEL SR64																
(1)	DOOR BUZZER		TRINE, MODEL 240																
(1)	KICKPLATE		HIAWATHA, MODEL KP834-US32D																
SET 4 - MANAGER'S OFFICE																			
(3)	HINGE		STANLEY, MODEL FBB179-4.5-US26 (06-8438)																
(1)	LOCKSET		SCHLAGE, MODEL L9453L-06A-626																
(1)	TEMP CORE		SCHLAGE, MODEL 80-035 INTERCHANGEABLE CORE (FINISH: BRUSHED CHROME)																
(1)	KICKPLATE		HIAWATHA, MODEL KP834-32D																
(1)	DOOR STOP		DON-JO, MODEL 1407-630, STAINLESS STEEL																
(3)	DOOR SILENCERS		IVES, MODEL SR64																
(1)	SECURITY WINDOW		AIR LOUVERS, MODEL VSL1212TEMPPAK SLIMLINE 12" X 12" X 1/4" LITE KIT (10" X 10" GLASS VISIBLE)																
SET 5A - UNISEX 2 - SINGLE OCCUPANT - KEYPAD PRIVACY LOCK																			
(3)	HINGE		STANLEY, MODEL FBB179-4.5-US26D (06-8438)																
(1)	CLOSER		FALCON, MODEL: SC61xRW/PaxALU																
(1)	LOCKSET		SCHLAGE, MODEL CO-100-CY-40-KP-RHO-626-PD																
(1)	DOOR STOP		DON-JO, 1407-630																
(3)	DOOR SILENCERS		IVES, MODEL SR64																
(2)	KICKPLATE		HIAWATHA, MODEL KP834-US32D																
(1)	COAT HOOK		MILLS, MODEL FT6519, SUPPLIED BY WASHROOM ACCESSORIES VENDOR, MOUNT T.O. HOOK AT 47 1/2" AFF																
SET 6A - UNISEX 1 - SINGLE OCCUPANT - KEYPAD PRIVACY LOCK																			
(3)	HINGE		STANLEY, MODEL FBB179-4.5-US26D (06-8438)																
(1)	CLOSER		FALCON, MODEL: SC61xRW/PaxALU																
(1)	LOCKSET		SCHLAGE, MODEL CO-100-CY-40-KP-RHO-626-PD																
(1)	DOOR STOP		DON-JO, 1407-630																
(3)	DOOR SILENCERS		IVES, MODEL SR64																
(2)	KICKPLATE		HIAWATHA, MODEL KP834-US32D																
(1)	COAT HOOK		MILLS, MODEL FT6519, SUPPLIED BY WASHROOM ACCESSORIES VENDOR, MOUNT T.O. HOOK AT 47 1/2" AFF																

DOOR NOTES																DOOR FRAMES		CUSTOM WOOD PULL	
1. ALL EGRESS DOORS SHALL BE READILY OPENABLE FROM THE EGRESS SIDE WITHOUT THE USE OF A KEY OR SPECIAL KNOWLEDGE OR EFFORT.																RE: DOOR SCHED		RE: DOOR SCHED	
2. LATCHES, HANDLES, PANIC BARS AND ALL DOOR HARDWARE WILL COMPLY WITH SECTION 7.2 OF NFPA 101 PER THE SPECIFICATIONS.																SEE WINDOW TYPES			
3. THE MANAGER HAS A KEY TO UNLOCK RESTROOM DOORS, FROM THE OUTSIDE IN CASE OF AN EMERGENCY.																2"		2"	
4. ALL DOORS TO REMAIN UNLOCKED DURING BUSINESS HOURS.																2"		2"	
5. SEE THIS SHEET FOR EXTERIOR DOOR SIGNAGE INFO.																2"		2"	
6. MAXIMUM EFFORT TO OPERATE EXTERIOR OR INTERIOR DOORS WITH CLOSERS SHALL NOT EXCEED 5 POUNDS. THIS MAY BE INCREASED TO 15 POUNDS FOR FIRE-RATED DOORS.																2"		2"	
7. ALL FRAMES, DOORS AND HARDWARE TO BE FURNISHED BY TENANT HARDWARE SUPPLIER AND INSTALLED BY TENANT G.C. CALL PETE KLIMEK WITH TWIN CITY HARDWARE AT 763-525-4660 TO ARRANGE DELIVERY. STOREFRONT DOORS ARE TO BE PROVIDED BY G.C., STOREFRONT HARDWARE PROVIDED BY TENANT HARDWARE SUPPLIER.																2"		2"	
8. THE BOTTOM 10 INCHES OF ALL DOORS SHALL HAVE A SMOOTH, UNINTERRUPTED SURFACE TO ALLOW THE DOOR TO BE OPENED BY A WHEELCHAIR FOOTREST WITHOUT CREATING A TRAP OR HAZARDOUS CONDITION.																2"		2"	
9. ALL SUPPORT SIGNAGE PROVIDED BY TENANT'S SUPPORT SIGNAGE SUPPLIER.																2"		2"	
10. ALL SUPPORT SIGNAGE INSTALLED BY G.C.																2"		2"	
11. ALL HARDWARE SHALL MATCH STOREFRONT, VERIFY WITH ARCHITECT PRIOR TO ORDERING																2"		2"	
DOOR TYPES																DOOR CLOSER			
RE: DOOR SCHED																RE: DOOR SCHED		RE: DOOR SCHED	
X" X"																EQ 10" EQ		EQ 10" EQ	
10"																10"		10"	
3' - 7"																3' - 7"		3' - 7"	
1/4" CLEAR TEMPERED GLASS																1/4" CLEAR TEMPERED GLASS		1/4" CLEAR TEMPERED GLASS	
KICK PLATES WHERE SCHEDULED																KICK PLATES WHERE SCHEDULED		KICK PLATES WHERE SCHEDULED	
5/8" UNDERCUT																5/8" UNDERCUT		5/8" UNDERCUT	
A																B		C	
ALUMINUM DOOR W/ TEMPERED GLAZING																HOLLOW METAL DOOR		INSULATED HOLLOW METAL DOOR	
D																			
INSULATED HOLLOW METAL DOOR																			
TOP JAMB MOUNT INSTALLATION. (NOTE THAT BACKPLATE IS MISSING IN THIS INSTALLATION BECAUSE HEAD JAMB IS OF ADEQUATE HEIGHT TO RECEIVE ALL MOUNTING SCREWS WITHOUT IT.) WHEN IN DOUBT ABOUT THE HEAD JAMB DIMENSION OR STABILITY, ORDER THE BACKPLATE.																			

DOOR SCHEDULE																REMARK NOTES		TYPICAL EXTERIOR DOOR TYPES	
SET 1 - MAIN ENTRY - PAIR - WOOD PULL/PUSH																			
(2)	HINGE		HAGER, MODEL 780-224HD-83"-CLR																
(2)	MORTISE CYLINDER		SCHLAGE, MODEL 80-103, BRUSHED CHROME; C.O. CYLINDER AT 34" MIN. FROM BOTTOM OF DOOR																
(2)	TEMP CORE		SCHLAGE, MODEL 80-035 INTERCHANGEABLE CORE, (BRUSHED CHROME)																
(2)	PUSH HARDWARE		1 1/2" DIAMETER WOOD PUSH, VARIES HIGH - PROVIDED BY MILLWORK SUPPLIER. MOUNT TOP OF PULLS FLUSH WITH TOP OF GLAZING STOP IN DOOR, RE: SHOP DRAWINGS																
(2)	PULL HARDWARE		1 1/2" DIAMETER WOOD PULL, VARIES HIGH - PROVIDED BY MILLWORK SUPPLIER. MOUNT TOP OF PULLS FLUSH WITH TOP OF GLAZING STOP IN DOOR, RE: SHOP DRAWINGS																
(1)	DEADBOLT		ADAMS RITE, MODEL MS1850S-310-628																
(1)	EXIT INDICATOR		ADAMS RITE, MODEL 4089-00-130																
(1)	HEADER BOLT		ADAMS RITE, MODEL 4016-30-01																
(1)	THRESHOLD BOLT		ADAMS RITE, MODEL 4015-18-18																
(2)	CLOSER		DORMA, MODEL 8916-AF89P-689 (TOP JAMB), (ALUMINUM)																
(2)	DOOR STOP		IVES, MODEL FS18S (ALUMINUM)																
(2)	OVERHEAD STOP		GLYNN-JOHNSON, MODEL 454S-SP28 (ALUMINUM)																
(2)	CLOSER BACK PLATE		DORMA, MODEL BP89, ALUMINUM																
(1)	THRESHOLD		REESE, MODEL S424A-72 (SIZE 72")																
(2)	SMOKE SEAL		REESE, MODEL 797B-21																
(2)	DOOR SWEEP		PEMKO, MODEL SFSC-200-36 (36" DOOR),OWNER FURNISHED																
SET 2A - ENTRY - SINGLE - NON-OFFSET - PANIC HARDWARE																			
(1)	HINGE		HAGER, MODEL 780-224HD-83"-CLR																
(1)	PUSH HARDWARE		ADAMS RITE, MODEL 8801-36-628 (ALUMINUM FINISH, 36" DOOR); C.O. EXIT DEVICE AT 38" FROM BOTTOM OF DOOR																
(1)	PULL HARDWARE		HAGER, MODEL 4G US32D (8" CTC), CENTER ON DOOR STILE																
(1)	CLOSER		DORMA, MODEL 8916-AF89P-689 (TOP JAMB), (ALUMINUM)																
(1)	CLOSER BACK PLATE		DORMA, MODEL BP89, ALUMINUM																
(1)	OVERHEAD STOP		GLYNN-JOHNSON, MODEL 454S-US32D (ALUMINUM)																
(1)	THRESHOLD		REESE, MODEL S424A-36 (SIZE 36")																
(1)	SMOKE SEAL		REESE, MODEL 797B-21																
(1)	DOOR SWEEP		PEMKO, MODEL SFSC-200-36 (36" DOOR), OWNER FURNISHED																
(1)	DOOR STOP		IVES, MODEL FS18S (ALUMINUM)																
SET 2B - ENTRY - SINGLE - EGRESS ONLY - PANIC HARDWARE																			
(1)	HINGE		HAGER, MODEL 780-224HD-83"-CLR																
(1)	PUSH HARDWARE		ADAMS RITE, MODEL 8801-36-628 (ALUMINUM FINISH, 36" DOOR); C.O. EXIT DEVICE AT 38" FROM BOTTOM OF DOOR																
(1)	CLOSER		DORMA, MODEL 8916-AF89P-689 (TOP JAMB), (ALUMINUM)																
(1)	CLOSER BACK PLATE		DORMA, MODEL BP89, ALUMINUM																
(1)	OVERHEAD STOP		GLYNN-JOHNSON, MODEL 454S-US32D (ALUMINUM)																
(1)	THRESHOLD		REESE, MODEL S424A-36 (SIZE 36")																
(1)	SMOKE SEAL		REESE, MODEL 797B-21																
(1)	DOOR SWEEP		PEMKO, MODEL SFSC-200-36 (36" DOOR), OWNER FURNISHED																
(1)	DOOR STOP		IVES, MODEL FS18S (ALUMINUM)																
SET 3 - REAR EXIT - SINGLE																			
(1)	HINGE		HAGER, MODEL 780-224HD-83"-CLR																
(1)	PUSH HARDWARE		FALCON, MODEL 25-R-EQ-4"-US28 (SIZE 42")																
(1)	PULL HARDWARE		FALCON, MODEL S10L-DANE-LHR-US26D, ALUMINUM (EXTERIOR SIDE)																
(1)	RIM CYLINDER		GLS, MODEL RCIC-7-LZ-626																
(1)	TEMP CORE		SCHLAGE, MODEL 80-035 INTERCHANGEABLE CORE (FINISH: BRUSHED CHROME)																
(1)	CLOSER		DORMA, MODEL 8916-AF89P-689 (TOP JAMB), ALUMINUM																
(1)	CLOSER BACK PLATE		DORMA, MODEL BP89, ALUMINUM																
(1)	THRESHOLD		REESE, MODEL S239A-42, (SIZE 42")																
(1)	WEATHERSTRIP		REESE, MODEL D575C-4070																
(1)	DOOR SWEEP		PEMKO, MODEL SFSC-200-42 (42" DOOR) (BLACK) OWNER FURNISHED																
(1)	DOOR VIEWER		IVES, MODEL U698826D, C.O. VIEWER AT 60" FROM BOTTOM OF DOOR																
(1)	EXIT ALARM		TRINE, MODEL 206-3																
(1)	DOOR SILENCERS		IVES, MODEL SR64																
(1)	DOOR BUZZER		TRINE, MODEL 240																
(1)	KICKPLATE		HIAWATHA, MODEL KP834-US32D																
SET 4 - MANAGER'S OFFICE																			
(3)	HINGE		STANLEY, MODEL FBB179-4.5-US26 (06-8438)																
(1)	LOCKSET		SCHLAGE, MODEL L9453L-06A-626																
(1)	TEMP CORE		SCHLAGE, MODEL 80-035 INTERCHANGEABLE CORE (FINISH: BRUSHED CHROME)																
(1)	KICKPLATE		HIAWATHA, MODEL KP834-32D																
(1)	DOOR STOP		DON-JO, MODEL 1407-630, STAINLESS STEEL																
(3)	DOOR SILENCERS		IVES, MODEL SR64																
(1)	SECURITY WINDOW		AIR LOUVERS, MODEL VSL1212TEMPPAK SLIMLINE 12" X 12" X 1/4" LITE KIT (10" X 10" GLASS VISIBLE)																
SET 5A - UNISEX 2 - SINGLE OCCUPANT - KEYPAD PRIVACY LOCK																			
(3)	HINGE		STANLEY, MODEL FBB179-4.5-US26D (06-8438)																
(1)	CLOSER		FALCON, MODEL: SC61xRW/PaxALU																
(1)	LOCKSET		SCHLAGE, MODEL CO-100-CY-40-KP-RHO-626-PD																
(1)	DOOR STOP		DON-JO, 1407-630																
(3)	DOOR SILENCERS		IVES, MODEL SR64																
(2)	KICKPLATE		HIAWATHA, MODEL KP834-US32D																
(1)	COAT HOOK		MILLS, MODEL FT6519, SUPPLIED BY WASHROOM ACCESSORIES VENDOR, MOUNT T.O. HOOK AT 47 1/2" AFF																
SET 6A - UNISEX 1 - SINGLE OCCUPANT - KEYPAD PRIVACY LOCK																			
(3)	HINGE		STANLEY, MODEL FBB179-4.5-US26D (06-8438)																
(1)	CLOSER		FALCON, MODEL: SC61xRW/PaxALU																
(1)	LOCKSET		SCHLAGE, MODEL CO-100-CY-40-KP-RHO-626-PD																
(1)	DOOR STOP		DON-JO, 1407-630																
(3)	DOOR SILENCERS		IVES, MODEL SR64																
(2)	KICKPLATE		HIAWATHA, MODEL KP834-US32D																
(1)	COAT HOOK		MILLS, MODEL FT6519, SUPPLIED BY WASHROOM ACCESSORIES VENDOR, MOUNT T.O. HOOK AT 47 1/2" AFF																

DOOR SCHEDULE																REMARK NOTES		TYPICAL EXTERIOR DOOR TYPES	
SET 1 - MAIN ENTRY - PAIR - WOOD PULL/PUSH																			
(2)	HINGE		HAGER, MODEL 780-224HD-83"-CLR																
(2)	MORTISE CYLINDER		SCHLAGE, MODEL 80-103, BRUSHED CHROME; C.O. CYLINDER AT 34" MIN. FROM BOTTOM OF DOOR																
(2)	TEMP CORE		SCHLAGE, MODEL 80-035 INTERCHANGEABLE CORE, (BRUSHED CHROME)																
(2)	PUSH HARDWARE		1 1/2" DIAMETER WOOD PUSH, VARIES HIGH - PROVIDED BY MILLWORK SUPPLIER. MOUNT TOP OF PULLS FLUSH WITH TOP OF GLAZING STOP IN DOOR, RE: SHOP DRAWINGS																
(2)	PULL HARDWARE		1 1/2" DIAMETER WOOD PULL, VARIES HIGH - PROVIDED BY MILLWORK SUPPLIER. MOUNT TOP OF PULLS FLUSH WITH TOP OF GLAZING STOP IN DOOR, RE: SHOP DRAWINGS																
(1)	DEADBOLT																		

 DENOTES WOOD BLOCKING IN WALL BEHIND WALL MOUNTED OBJECT U.N.O.

1.	REFER TO SHEET A131 AND A132 FOR EQUIPMENT LIST AND FURNITURE SCHEDULE.
2.	REFER TO A130 FOR FINISH SCHEDULE.

A701



ELEVATION LEGEND

□ DENOTES WOOD BLOCKING IN WALL BEHIND WALL MOUNTED OBJECT U.N.O.

GENERAL NOTES

1. REFER TO SHEET A131 FOR EQUIPMENT LIST AND FURNITURE SCHEDULE.
2. PROVIDE FULL HEIGHT BLOCKING IN WALL FOR ALL SHELVING, TYP.
3. REFER TO A120 FOR FINISH SCHEDULE
4. REFER TO A201 AND ELECTRICAL DRAWINGS FOR LIGHT FIXTURE SCHEDULE.

Consultant:

R/A

RedArchitecture

589 W. NATIONWIDE BLVD. SUITE B
COLUMBUS, OHIO 43215 (614) 487-8770

FOR
CONSTRUCTION

COPYRIGHT 2023
THIS DRAWING IS AN INSTRUMENT OF SERVICE
AND AS SUCH REMAINS THE PROPERTY OF
CHIPOTLE MEXICAN GRILL, INC. PERMISSION FOR
USE OF THIS DOCUMENT IS LIMITED AND CAN BE
EXTENDED ONLY BY WRITTEN AGREEMENT WITH
CHIPOTLE MEXICAN GRILL, INC..



CHIPOTLE MEXICAN GRILL, INC.
PO BOX 182566
COLUMBUS, OH 43218-2566
TELEPHONE: 614.318.2400
INTERNET: WWW.CHIPOTLE.COM

STORE NO.: 4870
WALNUT HILLS
1202 E MCMILLAN STREET
CINCINNATI, OH 45206

Issue Record:

11/03/23 PERMIT SET
05/08/24 CONSTRUCTION SET

Revisions:

1 1/24/24 HEALTH COMMENTS

Drawn:

JTH,
PH

Checked:

TC

Project No.

CMG1144

Contents:

ELEVATIONS -
INTERIOR KITCHEN

A702

*THIS DETAIL IS FOR HANDSINK ACCESSORY DIMENSIONS ONLY. FOR ACTUAL
ORIENTATION OF HAND SINK AND ACCESSORIES, REFER TO KITCHEN ELEVATIONS

WALL FINISH VARIES,
REFER TO A120

PAPER TOWEL DISPENSER

TANK SOAP DISPENSER

HYGIENE DISPENSER

NOTE: REFER TO SHEET
G002 FOR ALL REQUIRED
ACCESSIBLE MOUNTING
HEIGHTS. CONTACT
ARCHITECT IMMEDIATELY
WITH ANY DISCREPANCIES

CLEANER SPARY BOTTLE
AND BRACKET, ALIGN
OUTER EDGE OF SPRAY
BOTTLE WITH OUTER EDGE
OF SINK ABOVE AND
BOTTOM OF BOTTLE WITH
ADI. SANITARY BUCKET

PROVIDE BLOCKING BEHIND
HAND SINK AND
ASSOCIATED OBJECTS
WHEN REQUIRED, REFER TO
ELEVATIONS ON THIS SHEET
FOR EXACT LOCATIONS

HAND SINK, INSTALL TWO
(2) SCREWS WITH FINISH
GROMMETS INTO
BACKPLASH. SCREWS TO
BE 1/4" x 3 1/2" STAINLESS
STEEL LAG BOLT WITH OVAL
HEAD AND STAINLESS STEEL
TRIM WASHER. PROVIDE
BLOCKING AS REQUIRED AT
EACH SCREW LOCATION

SANITARY BUCKET, ALIGN
OUTER EDGE OF BUCKET
WITH OUTER EDGE OF
PAPER TOWEL DISPENSER
ABOVE, MOUNT B.O.
BRACKET AS SHOWN.

TYP ELEV - HAND SINK

1/2" = 1'-0"

B.O. LAY-IN CEILING TILE
9'-6" AFF

ELEC PANEL
LOCATION, SEE
ELEC PLANS

STAINLESS
STEEL SHROUD,
REFER TO
FINISH PLAN

INT ELEV - KITCHEN

1/4" = 1'-0"

B.O. LAY-IN CEILING TILE
9'-6" AFF

SODA CHASE, TYP.
OF (2), REFER TO
PLUMBING
DRAWINGS

ENT ELEV - KITCHEN

1/4" = 1'-0"

B.O. LAY-IN CEILING TILE
9'-6" AFF

WATER FILTER ABOVE,
REFER TO PLUMBING
DRAWINGS

ENT ELEV - KITCHEN

1/4" = 1'-0"

B.O. LAY-IN CEILING TILE
9'-6" AFF

EXISTING TRANSOM
WINDOW WITH
FROSTED FILM

EXISTING REAR
ENTRY DOOR

ENT ELEV - KITCHEN

1/4" = 1'-0"

WATER FILTER
ABOVE, REFER TO
PLUMBING
DRAWINGS

LAY-IN CEILING - C4
± 9' - 4" AFF

ALUM. PLATE
JAMB, SILL, AND
HEADER AT
OPENING, REFER
TO 12 & 13/A802

EXISTING
STOREFRONT
DOOR

ENT ELEV - KITCHEN

1/4" = 1'-0"

LAY-IN CEILING - C4
± 9' - 4" AFF

ALUM. PLATE
JAMB, SILL, AND
HEADER AT
OPENING, REFER
TO 12 & 13/A802

ENT ELEV - KITCHEN

1/4" = 1'-0"

EXISTING WOOD
STRUCTURE

LAY-IN CEILING - C4
± 9' - 4" AFF

GYP. BD. CEILING - C3
± 9' - 0" AFF

DIFFUSER, REFER
TO MECHANICAL
DRAWINGS

ENT ELEV - KITCHEN

1/4" = 1'-0"

STAINLESS STEEL
SHROUD, REFER TO
FINISH PLAN

LAY-IN CEILING - C4
± 9' - 6" AFF

MOVEABLE LINEN
BINS WITH LID,
TYP. OF (4)

HANDSINK, REFER
TO 13/A702 FOR
DETAILS

CHIME/STROBE,
REFER TO ELECTRICAL
SEE 1/A703 FOR DETAILS

ORDERING BEYOND

SEE POS ELEV, 1/A703,
FOR DETAILS

TIMECLOCK, REFER
TO ELECTRICAL
DRAWINGS

ENT ELEV - KITCHEN

1/4" = 1'-0"

LAY-IN CEILING - C4
± 9' - 4" AFF

GYP. BD. CEILING - C3
± 9' - 0" AFF

B.O. SHELF
6'-2 1/2" AFF

B.O. SHELF
4'-6 1/2" AFF

B.O. LAY-IN CEILING
9'-4" AFF

ENT ELEV - KITCHEN

1/4" = 1'-0"

B.O. LAY-IN CEILING
9'-6" AFF

B.O. LAY-IN CEILING
9'-4" AFF

OPEN
BEYOND

ENT ELEV - KITCHEN

1/4" = 1'-0"

B.O. LAY-IN CEILING
9'-6" AFF

B.O. LAY-IN CEILING
9'-4" AFF

ALUM. PLATE
JAMB, SILL, AND
HEADER AT
OPENING,
REFER TO 12
& 13/A802

OPEN
BEYOND

ENT ELEV - KITCHEN

1/4" = 1'-0"

PICK-UP WINDOW
WITH INTEGRATED
AIR CURTAIN

MONITOR, INSTALLED
BY TENANT'S VENDOR

STAINLESS STEEL
SHROUD, REFER TO
FINISH PLAN

ALL BLOCKING FOR WALL MOUNTED
OBJECTS ON THIS WALL NEEDS TO BE
20GA METAL BLOCKING

GAS SHUT-OFF VALVE,
REFER TO PLUMBING

ENT ELEV - KITCHEN

1/4" = 1'-0"

ELEVATION LEGEND

DENOTES WOOD BLOCKING IN WALL BEHIND WALL MOUNTED OBJECT U.N.O.

GENERAL NOTES

- REFER TO SHEET A131 FOR EQUIPMENT LIST AND FURNITURE SCHEDULE.
- PROVIDE FULL HEIGHT BLOCKING IN WALL FOR ALL SHELVING, TYP.
- REFER TO A120 FOR FINISH SCHEDULE
- REFER TO A201 AND ELECTRICAL DRAWINGS FOR LIGHT FIXTURE SCHEDULE.

Consultant:

R/A

RedArchitecture

589 W. NATIONWIDE BLVD. SUITE B
COLUMBUS, OHIO 43215 (614) 487-8770

FOR
CONSTRUCTION

COPYRIGHT 2023
THIS DRAWING IS AN INSTRUMENT OF SERVICE
AND AS SUCH REMAINS THE PROPERTY OF
CHIPOTLE MEXICAN GRILL, INC.. PERMISSION FOR
USE OF THIS DOCUMENT IS LIMITED AND CAN BE
EXTENDED ONLY BY WRITTEN AGREEMENT WITH
CHIPOTLE MEXICAN GRILL, INC..



CHIPOTLE MEXICAN GRILL, INC.
PO BOX 182566
COLUMBUS, OH 43218-2566
TELEPHONE: 614.318.2400
INTERNET: WWW.CHIPOTLE.COM

STORE NO.: 4870
WALNUT HILLS
1202 E MCMILLAN STREET
CINCINNATI, OH 45206

Issue Record:

11/03/23 PERMIT SET
05/08/24 CONSTRUCTION SET

Revisions:

Drawn: JTH, PH
Checked: TC


Project No.

CMG1144


Contents:

ELEVATIONS -
INTERIOR KITCHEN

A703

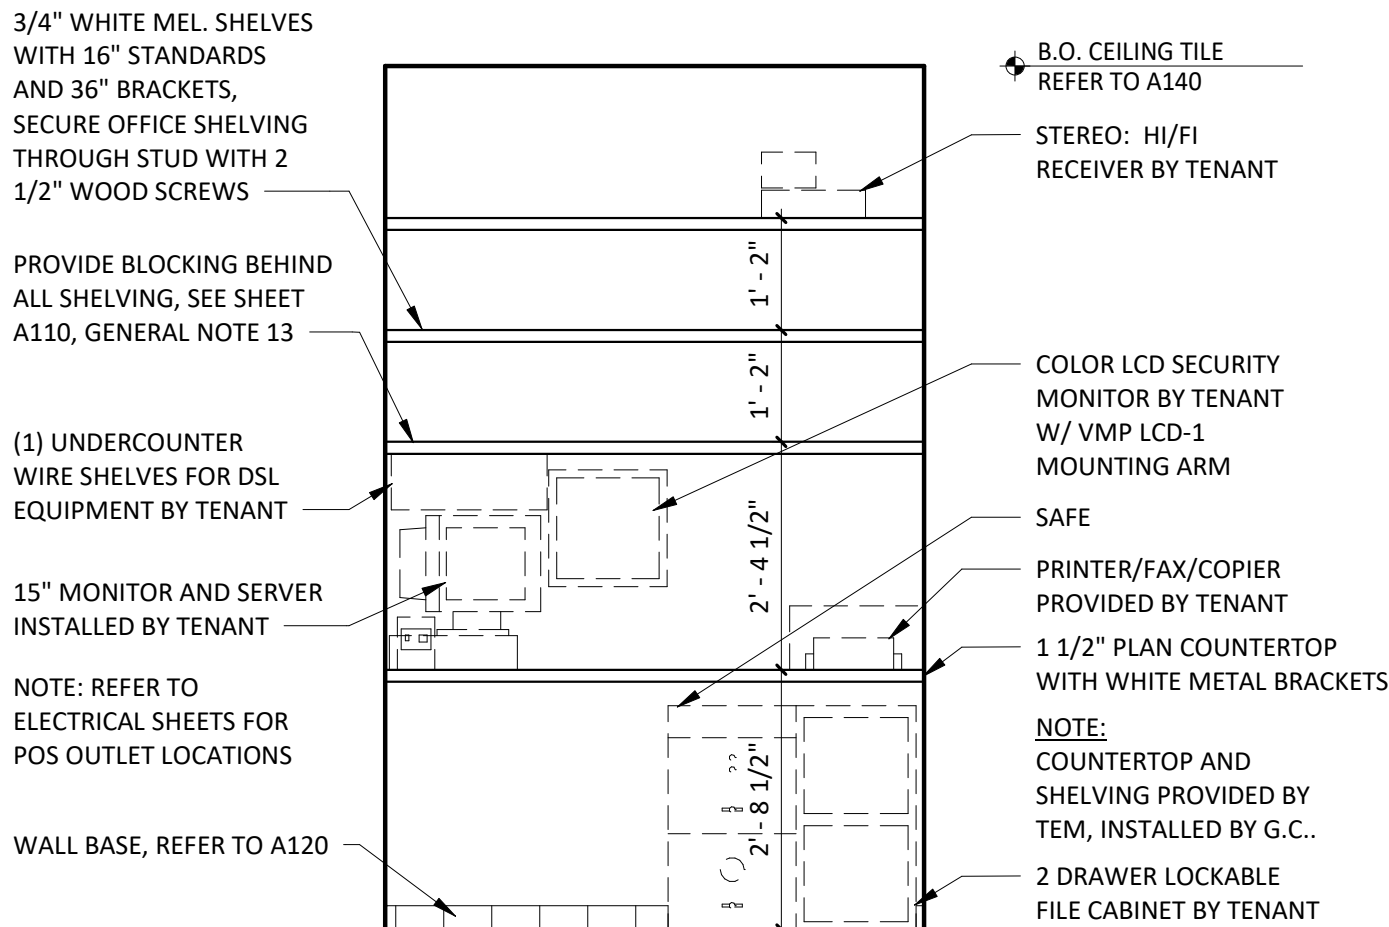

2
A703
TYP. ELEV - OFFICE SHELVING
1/2" = 1'-0"

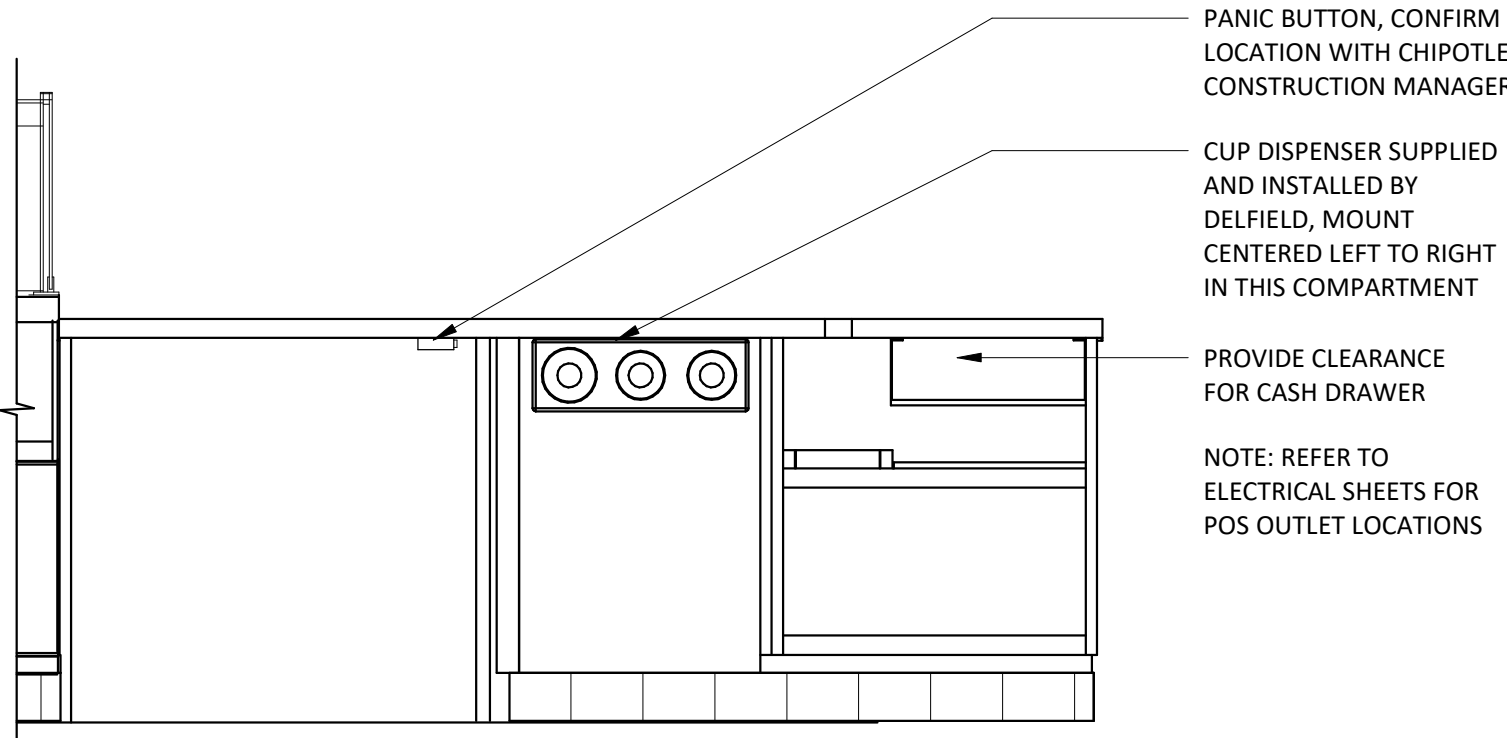

1
A703
TYP. ELEV - POS
3/4" = 1'-0"


ITEM #	DESCRIPTION	MANUF	MODEL	QTY	PROVIDED BY	INSTALLED BY	UTILITY				MOUNTING HEIGHT	REMARKS
							ELEC	GAS	WATER	SEWER		
1A	Grab Bar - 36in	ASI	3501-36	2	WA	GC					36" AFF to Top of Grasping Surface	Provide Plywood Blocking to Mount to Wall
1C	Grab Bar - 18in	ASI	3501-18	2	WA	GC					40" AFF to Centerline of Bottom Return	Provide Plywood Blocking to Mount to Wall
1D	Grab Bar - 48in	ASI	3501-48	2	WA	GC					36" AFF to Top of Grasping Surface	Provide Plywood Blocking to Mount to Wall
3	Vandal Proof Mirror	Sentry Mirror	20" x 30" Vandal Proof Mirror	2	TS	GC					Bottom Edge of Reflecting Surface at 40" AFF	Provide Plywood Blocking to Mount to Wall
5	Touch-Free Soap Dispenser	Purell	CS8	2	WA	GC					47 1/2" AFF to Top of Unit	
7	Recessed Toilet Paper Dispenser	ASI	0031	2	WA	GC					29" AFF to Top of Unit	Recess Mounted in Wall - Rough Opening: 6 1/4"W X 12 1/4"H X 3 3/8"D Top of Rough Opening: 29 1/4" AFF
8	Utility Shelf	ASI	0692	2	WA	GC					46" AFF To Top Of Shelf	Provide Toggle Bolts to Mount to Wall
9	Recessed Convertible Paper Towel Dispenser and Waste Receptacle, Recess Mounted in Wall	Bobrick	B-3944	2	WA	GC					Bottom of Unit at Top of Base, Bottom of Dispenser to be at 40" AFF, Recess Mounting In Wall	Rough Opening: 16"W x 54 3/4"H x 4" D. Provide Plywood Blocking to Mount to Wall
12	Napkin Disposal - Recessed	ASI	0473	2	WA	GC					Top of Rough Opening @ 29" AFF	Recess Mounted in Wall - Rough Opening: 11 1/4"W X 15 3/4"H X 4"D
14	Restroom Hand Sink	Kohler	K-2084	2	GC	GC				●	Mount Bottom of Front Edge Of The Sink At Exactly 29" AFF	
14.1	Restroom Hand Sink Faucet	T&S	EC-3102-TMV-LF-05	2	KES	GC				●		To Be Furnished With .5 GPM Aerator Installed. Thermostatic mixing valve is also included.
15	Hand Sanitizer Dispenser	Purell	ES8	2	WA	GC					Align T.O. Unit With T.O. Soap Dispenser	
16a	Surface Mounted Horizontal Baby Changing Station	Koala Care	KB200-05	2	WA	GC					Mount Bottom of Open Changing Bed at Exactly 27" AFF	GC to Provide adequate blocking to support the baby changing equipment. Blocking shall be installed in such a manner to not damage or compromise the rated assembly of the existing wall construction

1. ALL DIMENSIONS ARE TO FACE OF STUD UNLESS OTHERWISE NOTES.
2. REFER TO A802 FOR TILE NOTES.
3. ALL ACCESSORIES SHALL BE AS MANUFACTURED BY AMERICAN SPECIALTIES INC OR TENANT APPROVED EQUIVALENT UNLESS DESIGNATED OTHERWISE. PROVIDE SOLID FRT WOOD BLOCKING AS NECESSARY FOR INSTALLATION PER MANUFACTURER'S RECOMMENDATIONS. SEE SHEET G002 FOR ACCESSIBILITY GUIDELINES & MOUNTING HEIGHT REQUIREMENTS.
4. REFER TO A120 FOR FINISH SCHEDULE.
5. REFER TO A120 AND ELECTRICAL DRAWINGS FOR LIGHT FIXTURE SCHEDULE.


 DENOTES WOOD BLOCKING IN WALL BEHIND WALL MOUNTED OBJECT U.N.O.






89 W. NATIONWIDE BLVD. SUITE B
COLUMBUS, OHIO 43215 (614) 487-8770

COPYRIGHT 2023
THIS DRAWING IS AN INSTRUMENT OF SERVICE
AND AS SUCH REMAINS THE PROPERTY OF
CHIPOTLE MEXICAN GRILL, INC.. PERMISSION FOR
USE OF THIS DOCUMENT IS LIMITED AND CAN BE
EXTENDED ONLY BY WRITTEN AGREEMENT WITH
CHIPOTLE MEXICAN GRILL, INC..

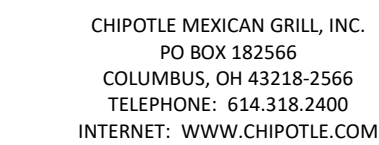[illegible]

 
A710



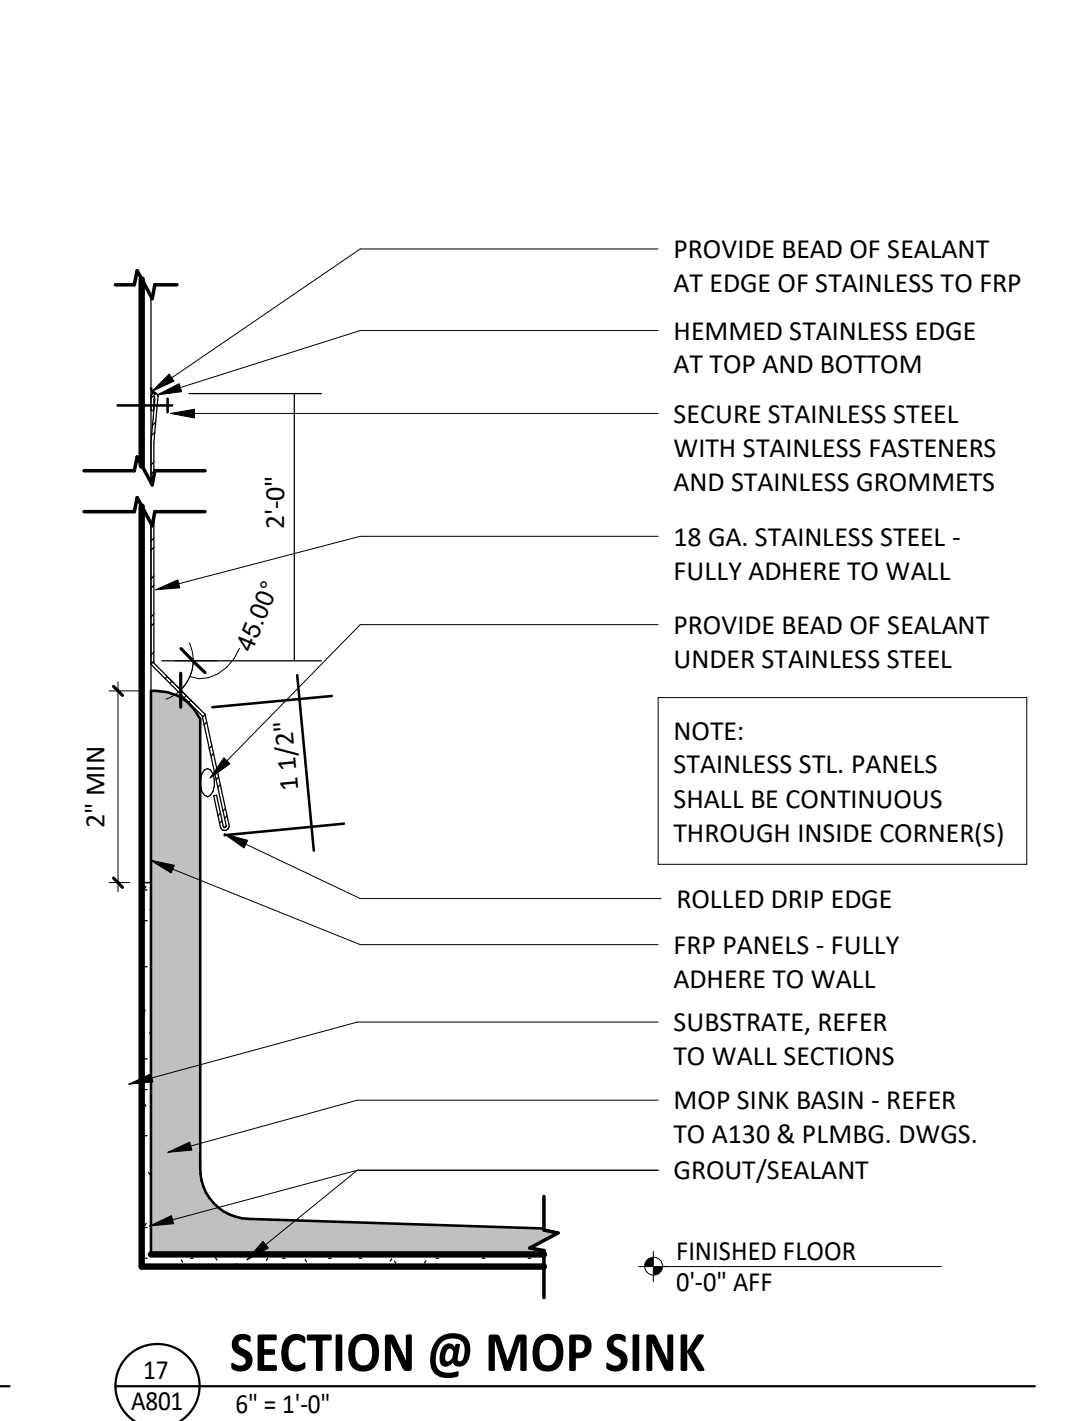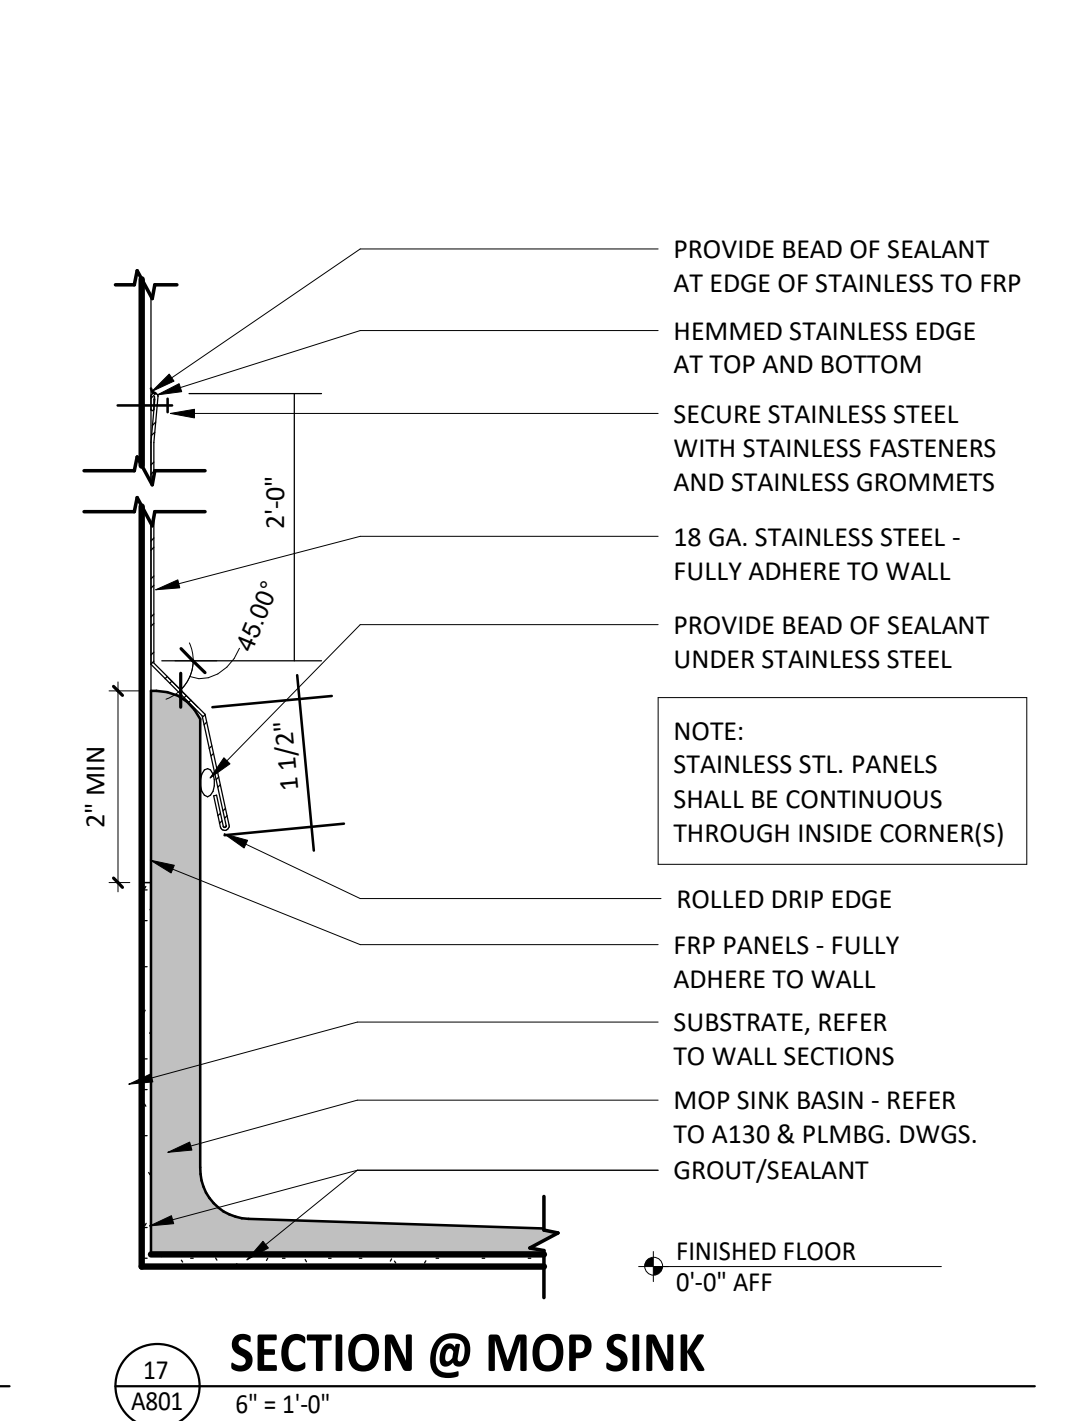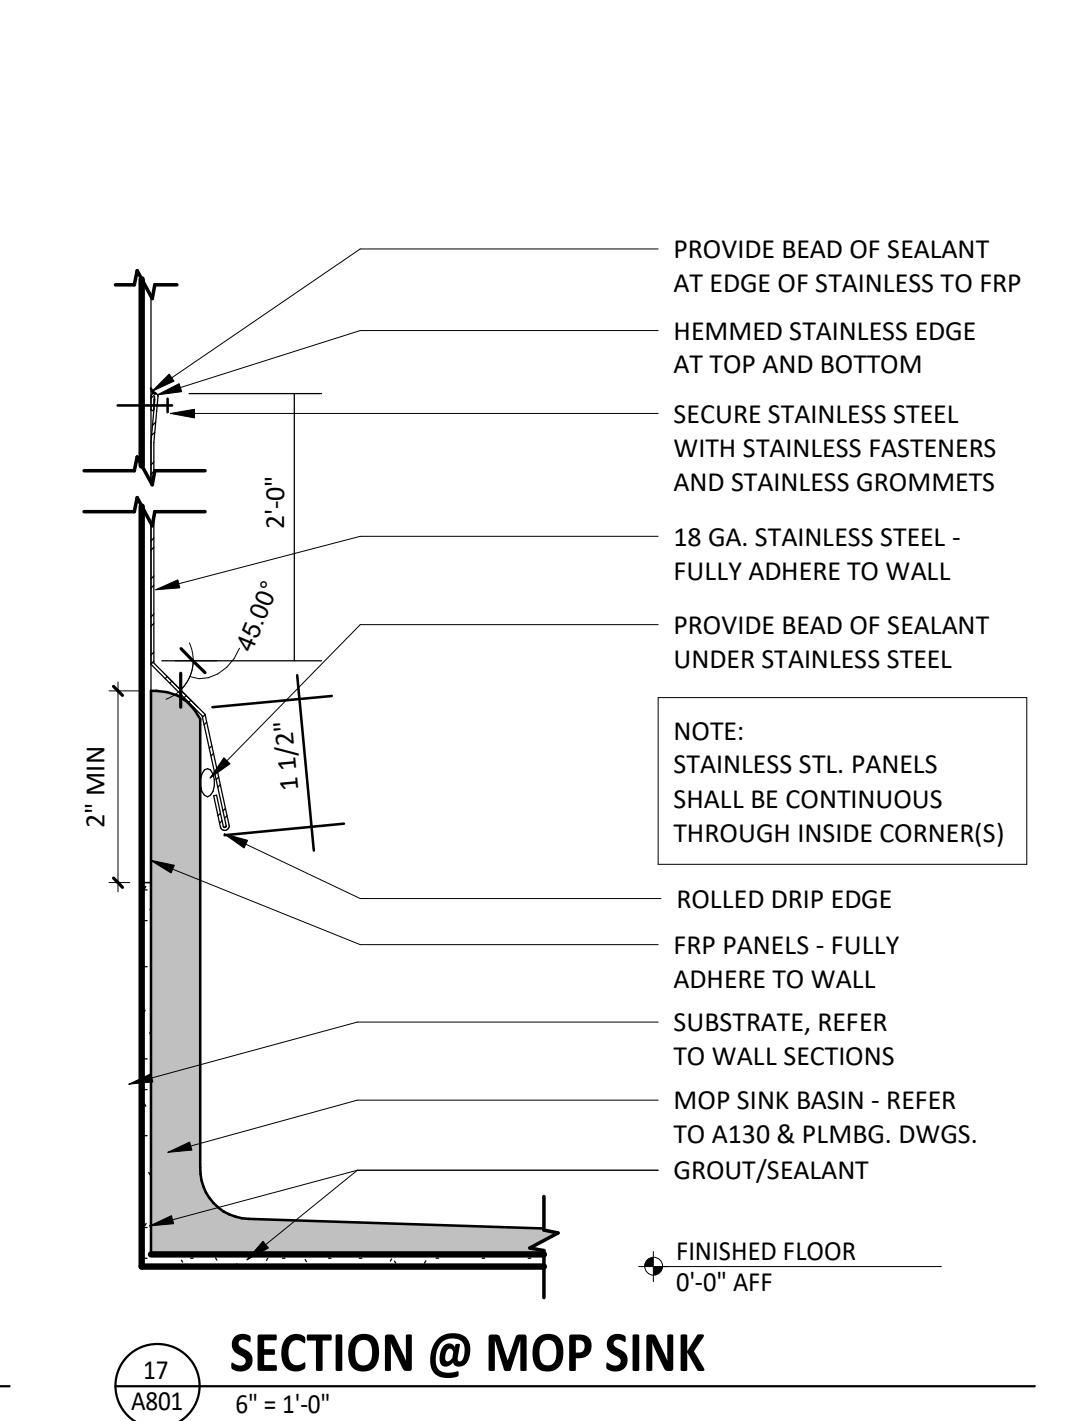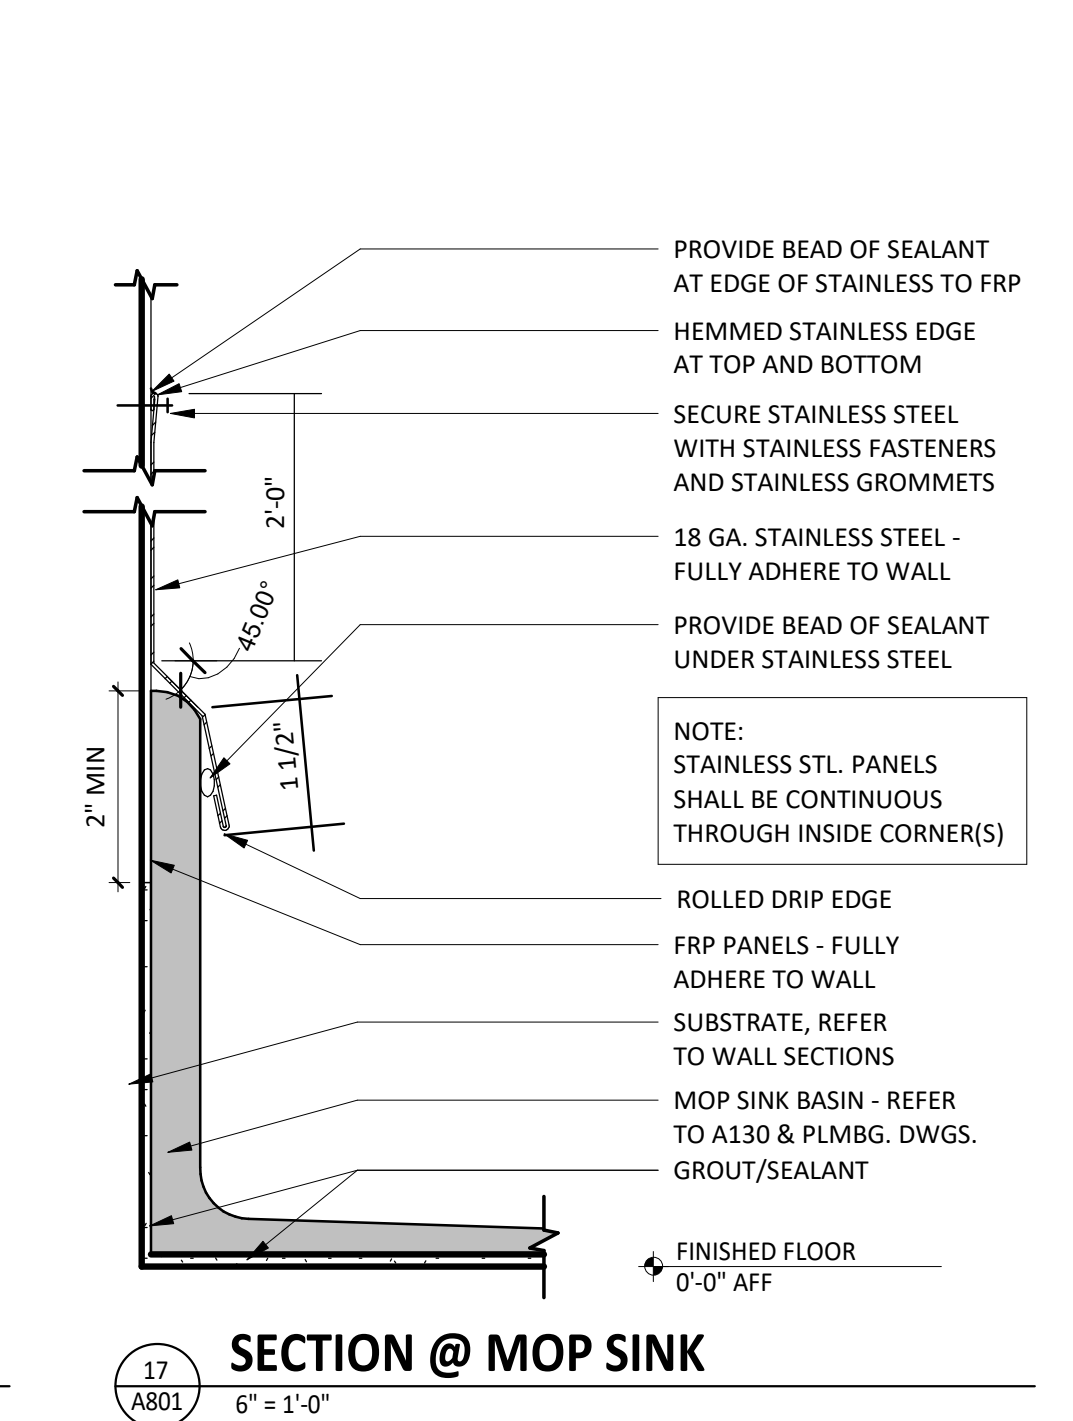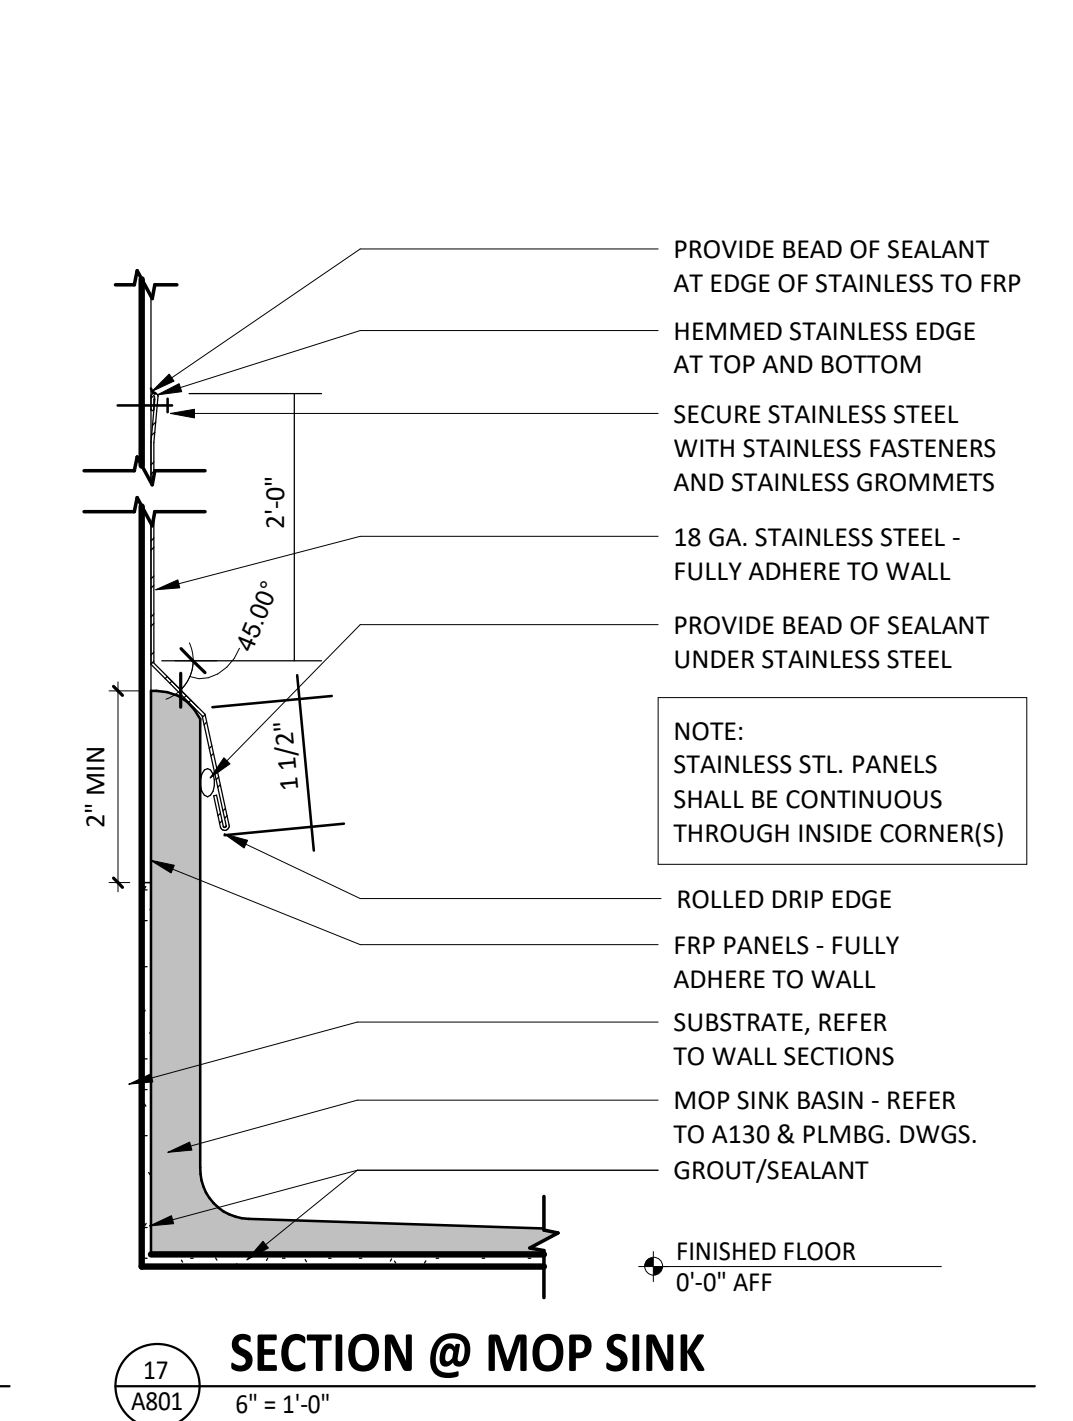


GENERAL NOTES


1. TILE INSTALLER SHALL COORDINATE WITH GENERAL CONTRACTOR AND PROVIDE LAYOUT OF ALL WALL TILE PRIOR TO INSTALLATION. GENERAL CONTRACTOR SHALL PREPARE WALLS AS TO NOT HAVE ANY CUT TILES IN EITHER DIRECTION (HORIZONTALLY OR VERTICALLY) ON ANY WALLS. LAYOUT SHALL BE APPROVED BY CHIPOTLE CM PRIOR TO INSTALLATION. CONTRACTOR SHALL CONTACT ARCHITECT OF ANY DISCREPANCIES IN DIMENSIONS FOR DIRECTION PRIOR TO INSTALLATION. FAILURE TO ADHERE TO THESE REQUIREMENTS RESULTING IN ANY REMEDIATION REQUIRED TO MEET DESIGN INTENT WILL BE AT CONTRACTOR'S COST.
2. IF REQUIRED TO CUT TILES, CONTRACTOR TO MEASURE OVERALL WALL WIDTH AND DETERMINE WHICH SOLUTION WILL ALLOW FOR THE GREATER THAN 25% TILE WIDTH AT WALL TERMINATIONS.
3. UNLESS OTHERWISE NOTED, ALL WALL TILES SHOULD BE CENTERED ON THE WIDTH OF THE WALL PER DETAIL 1 OR 2.
4. THERE SHOULD NEVER BE ANY CUT TILES VERTICALLY BETWEEN THE BASE AND THE CEILING. REFER TO A120 AND A201.

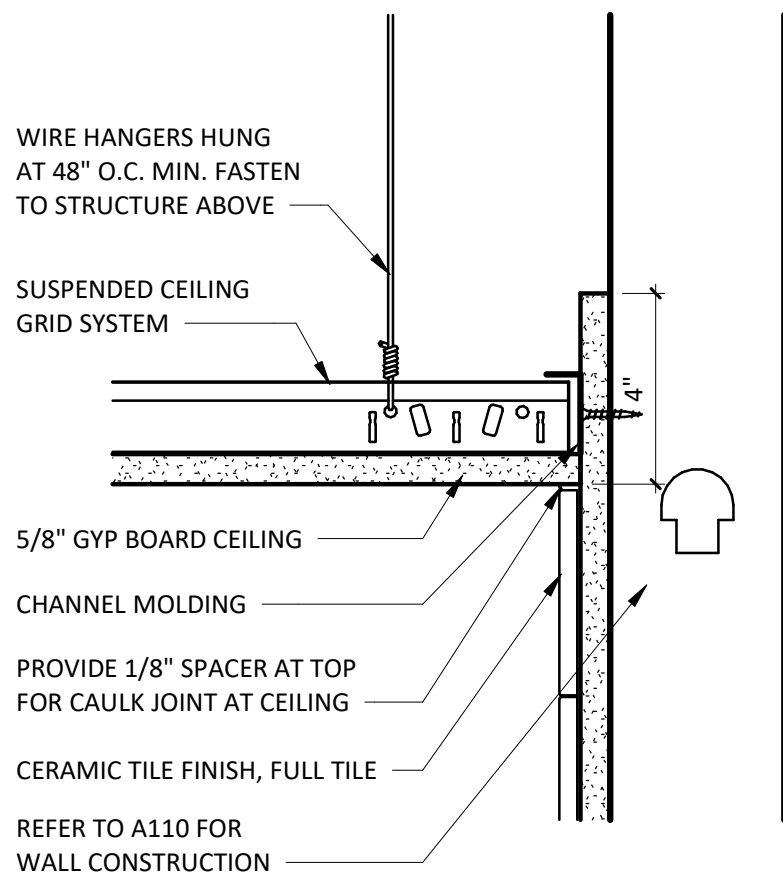


21
A802
TILE DETAIL @ GYP BD CEILING
3" = 1'-0"

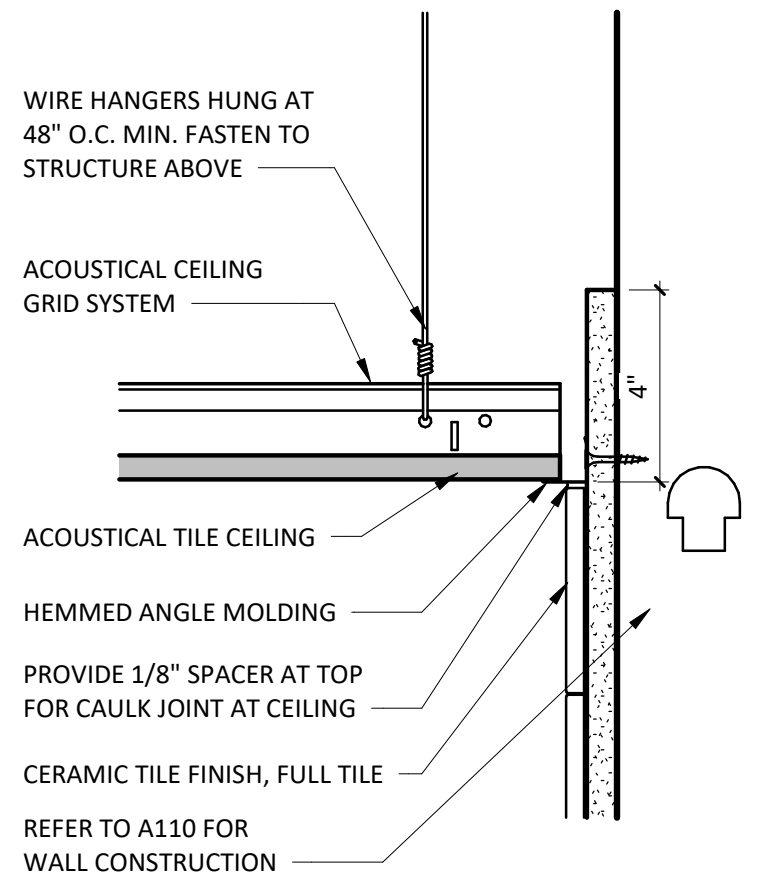

20
A802
TILE DETAIL @ SUSPENDED CEILING
3" = 1'-0"

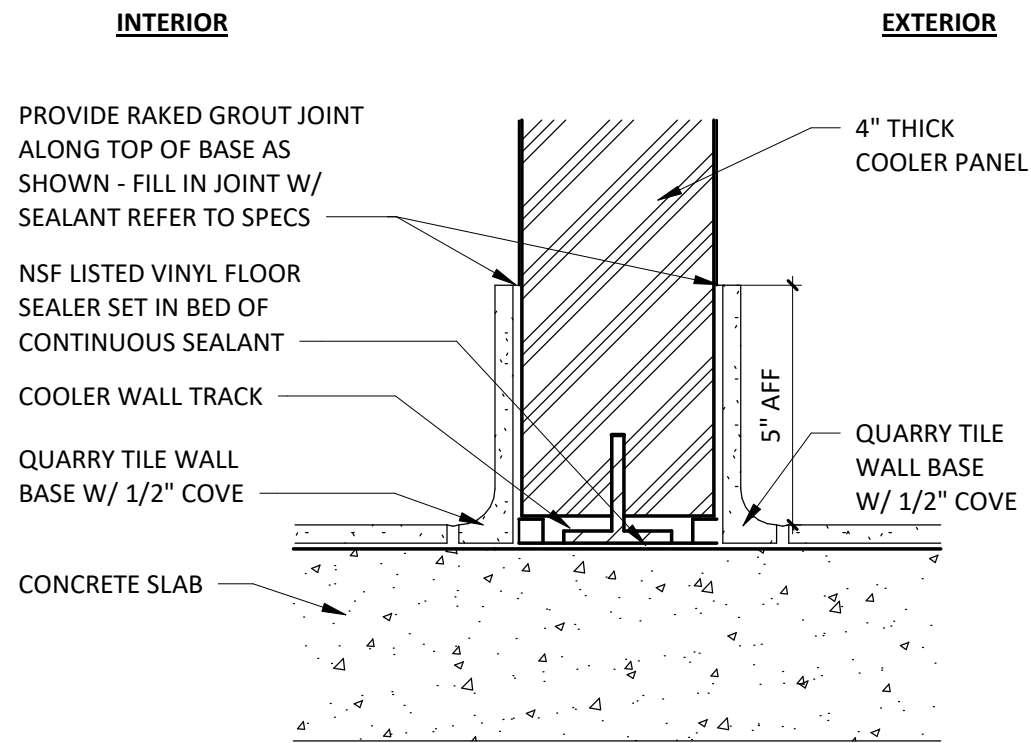


19
A802
COOLER WALL @ QT
3" = 1'-0"

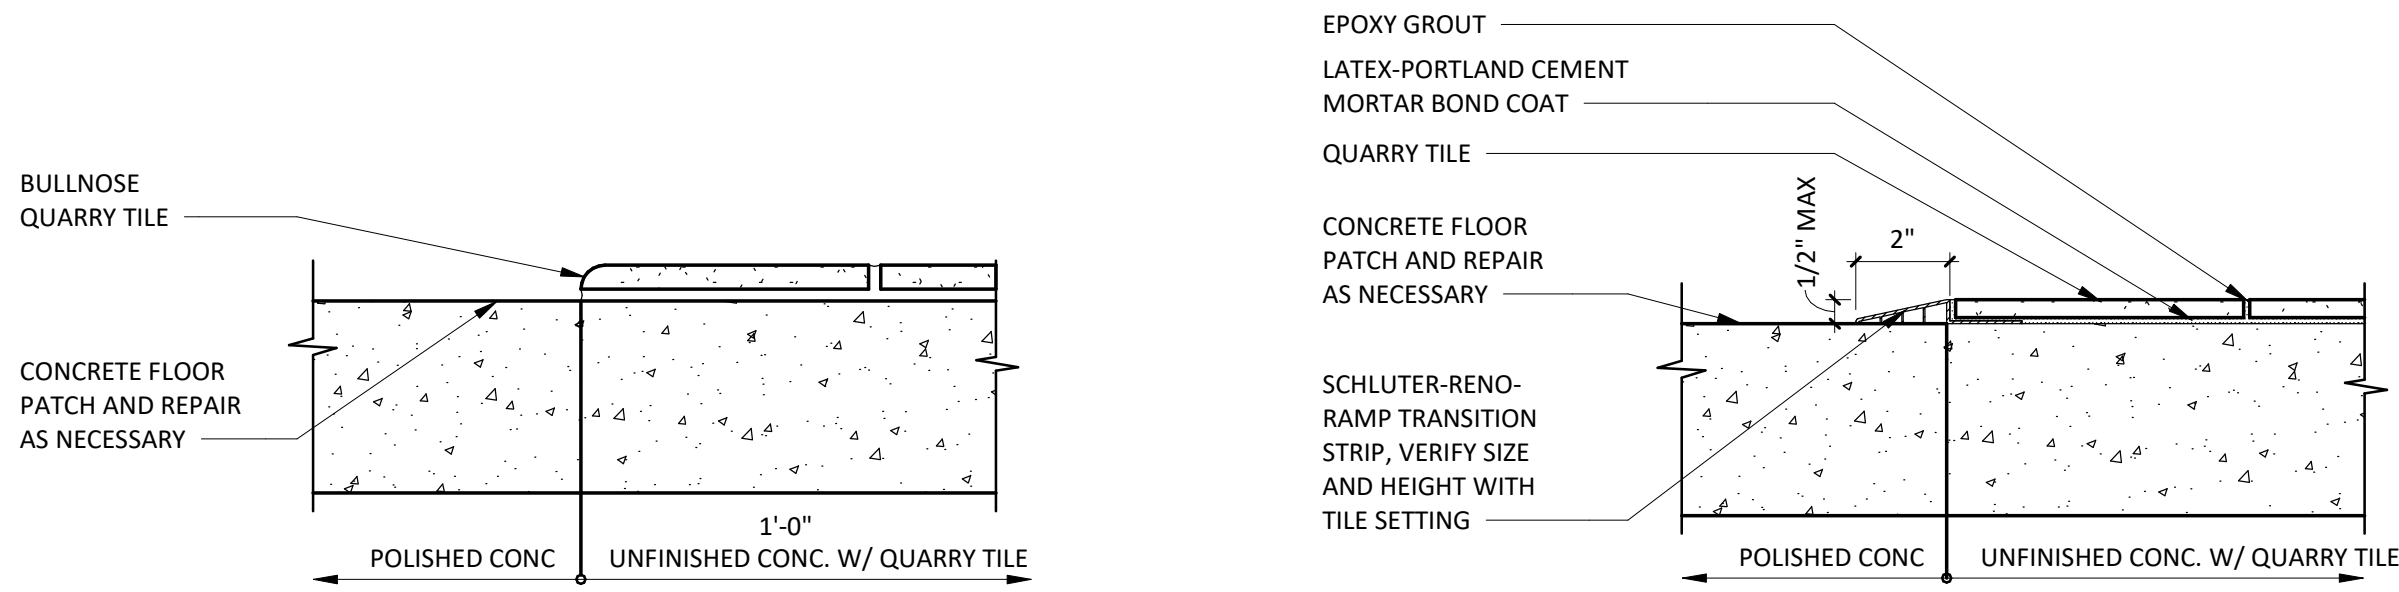


23
A802
FLOOR TRANSITION @ READY TO DRINK
3" = 1'-0"


22
A802
FLOOR TRANSITION W/ RAMP
3" = 1'-0"

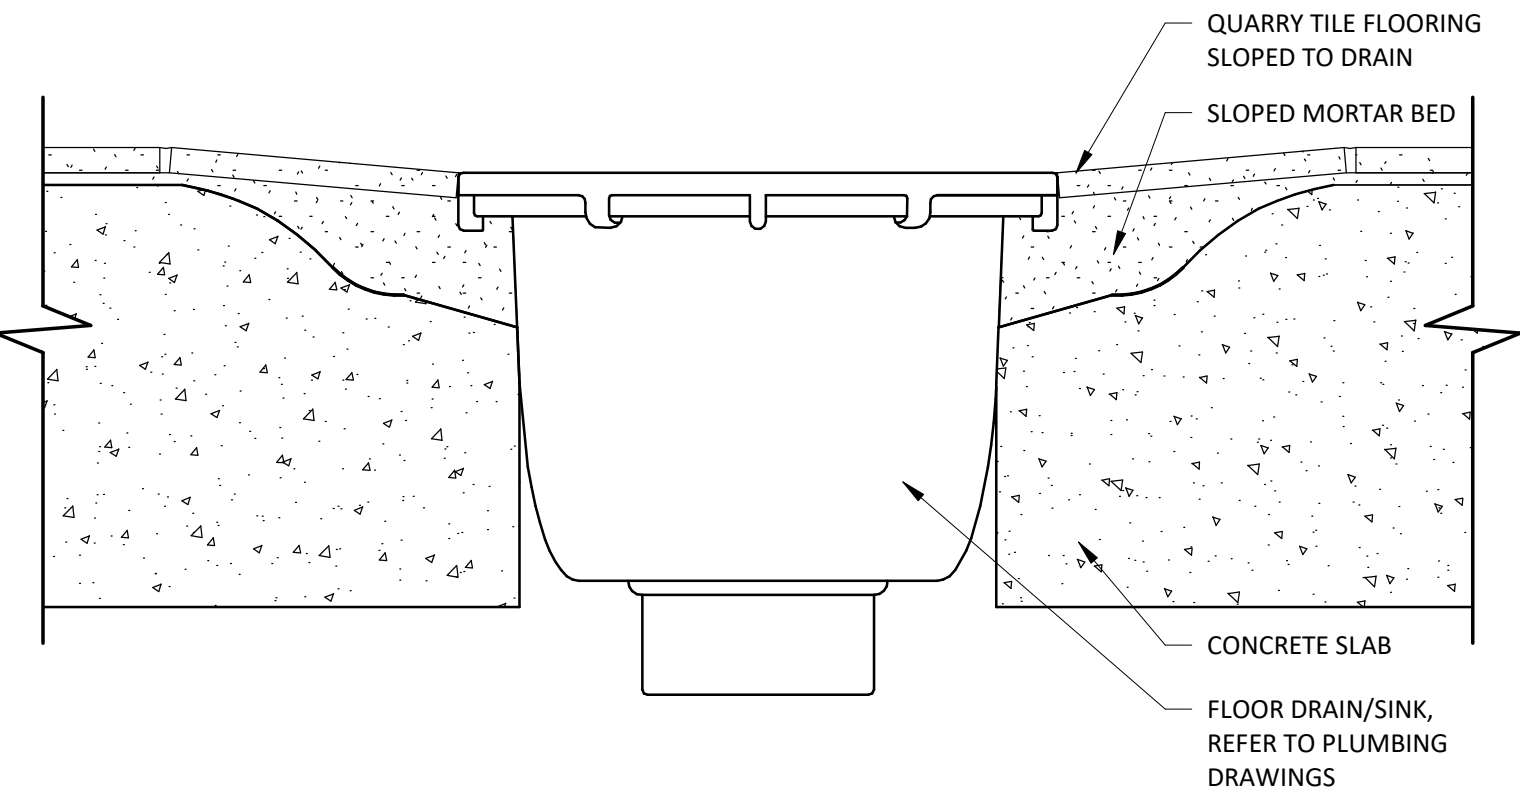


18
A802
TYPICAL QT FLOOR DRAIN/SINK DETAIL
3" = 1'-0"

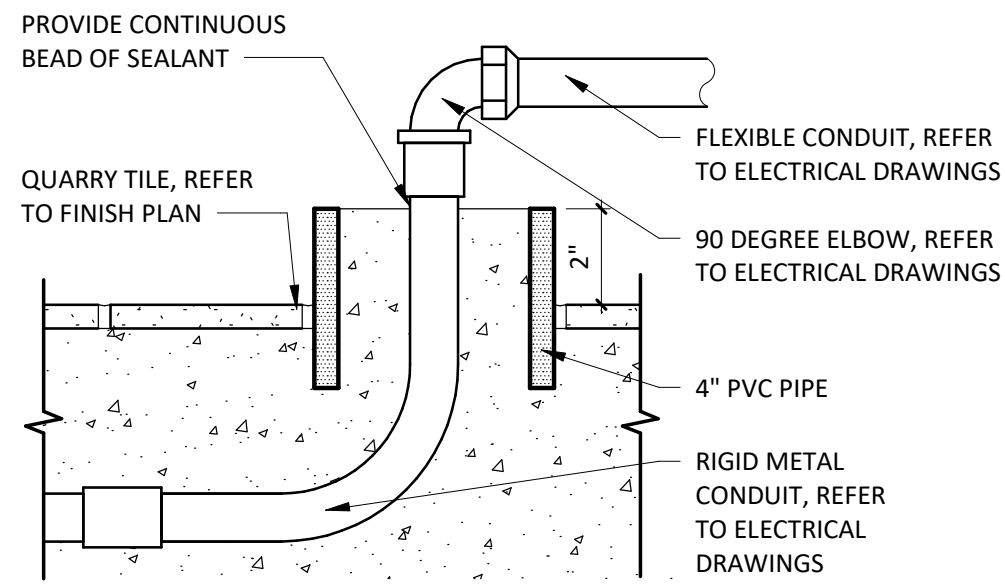


17
A802
STUB SECTION DETAIL UNDER TABLES
3" = 1'-0"

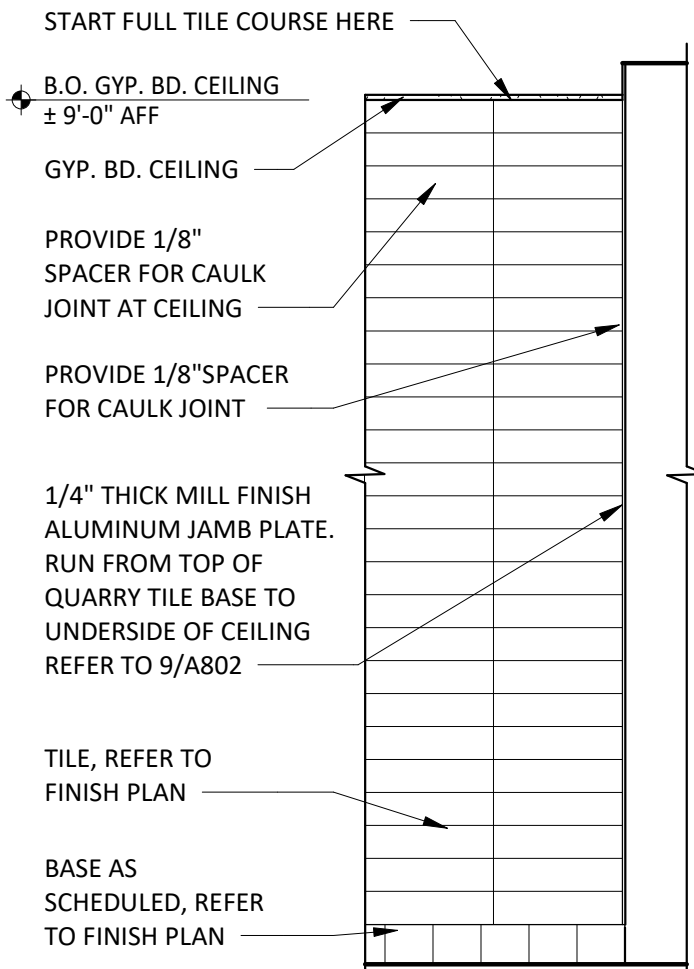


16
A802
KITCHEN WALL ENDCAP TILE LAYOUT
1/2" = 1'-0"

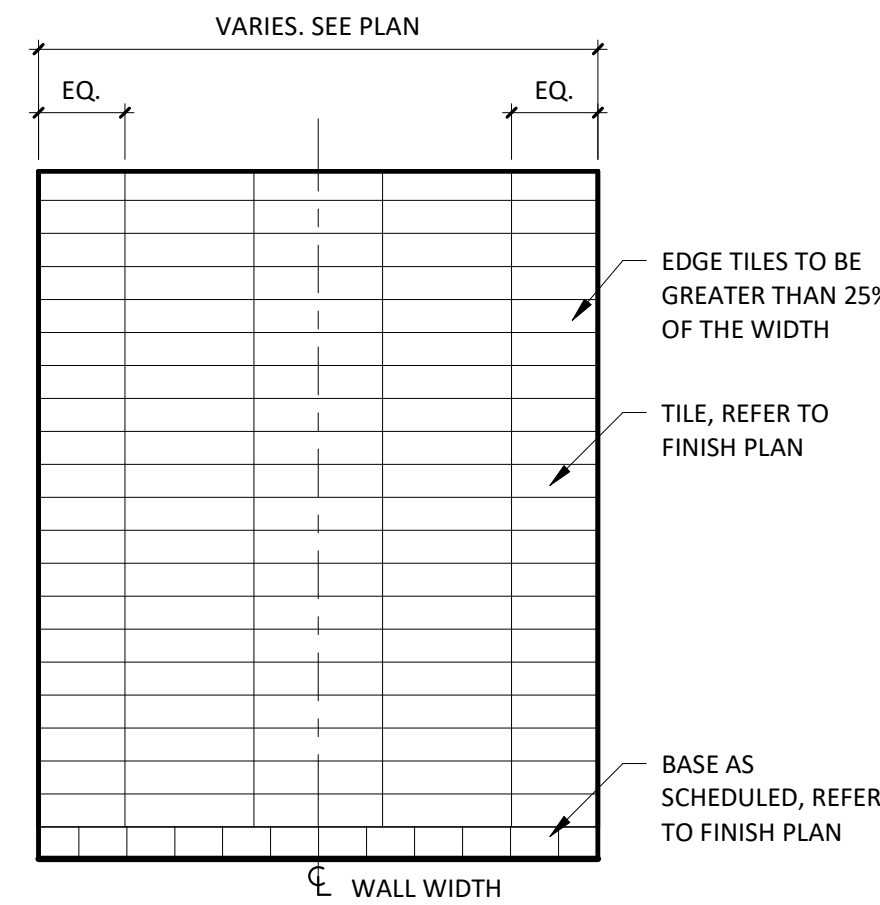


15
A802
TILE CENTERED LAYOUT
1/2" = 1'-0"

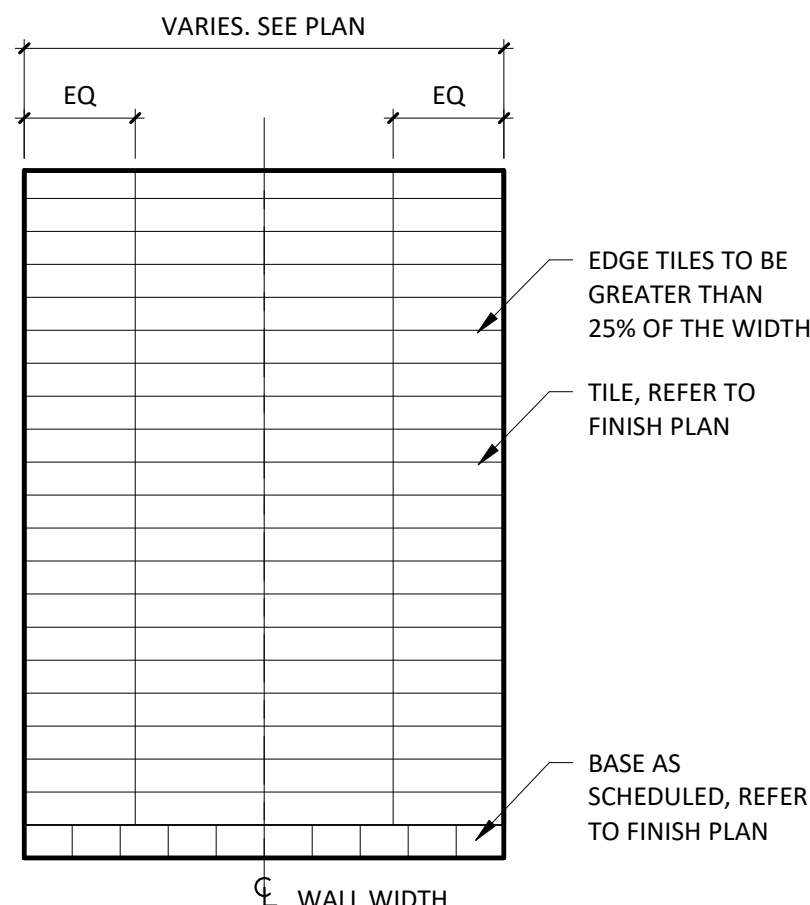


14
A802
JOINT CENTERED LAYOUT
1/2" = 1'-0"

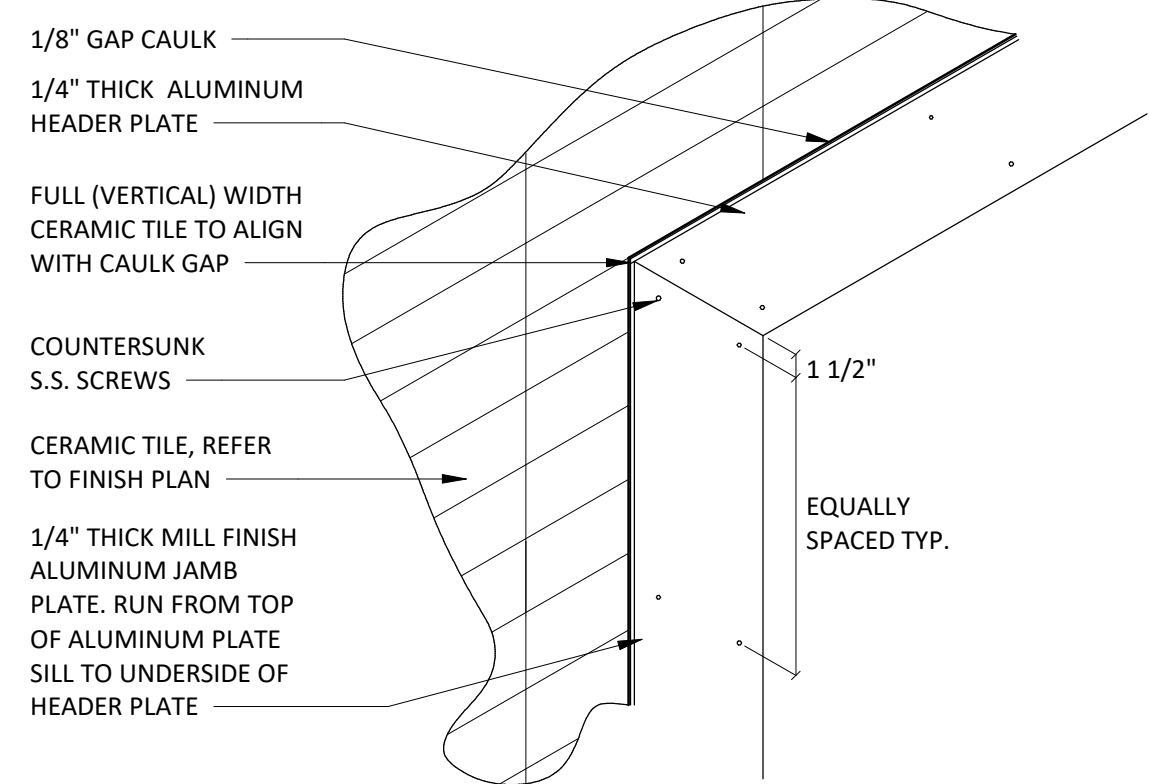


13
A802
TILE DETAIL @ ALUMINUM PLATE HEADER
1" = 1'-0"

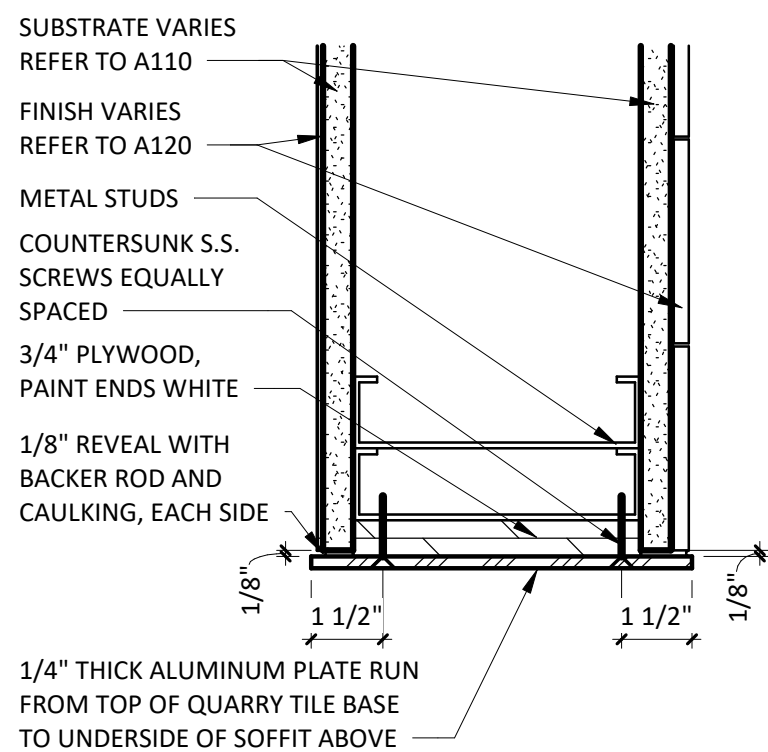


12
A802
ALUMINUM PLATE @ JAMB/HEAD/SILL
3" = 1'-0"

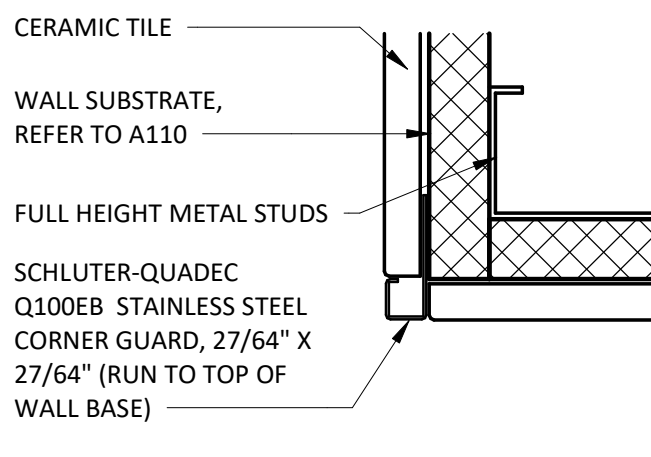


11
A802
TILE TO TILE OUTSIDE CORNER
6" = 1'-0"

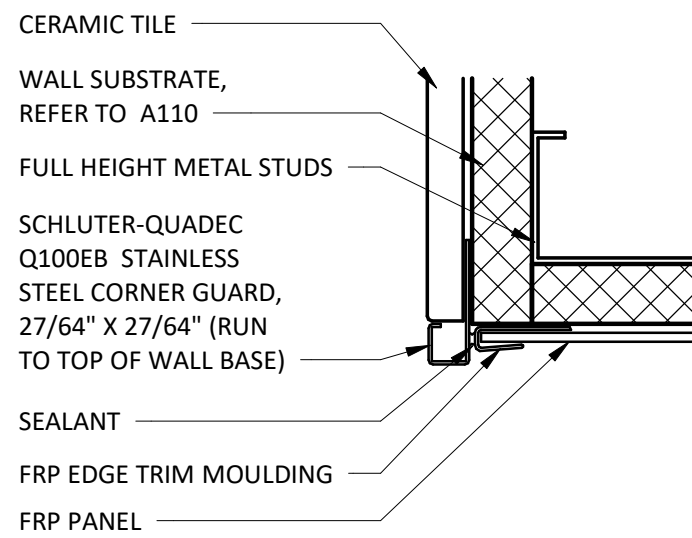


10
A802
TILE TO FRP OUTSIDE CORNER
6" = 1'-0"

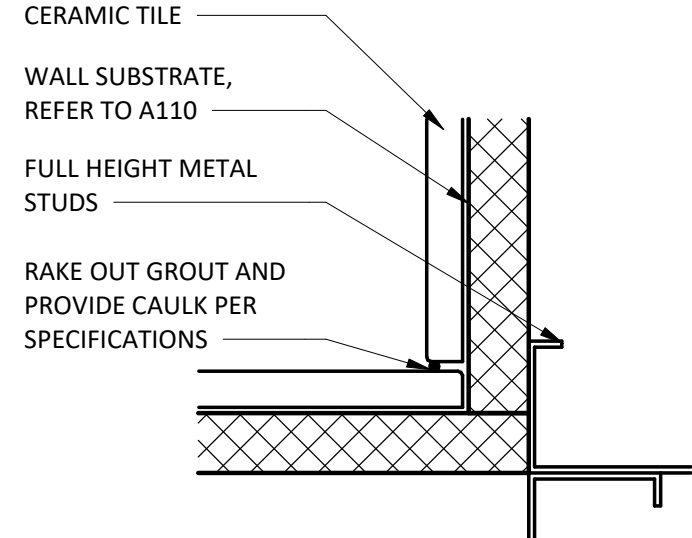


9
A802
TILE TO TILE INSIDE CORNER
6" = 1'-0"

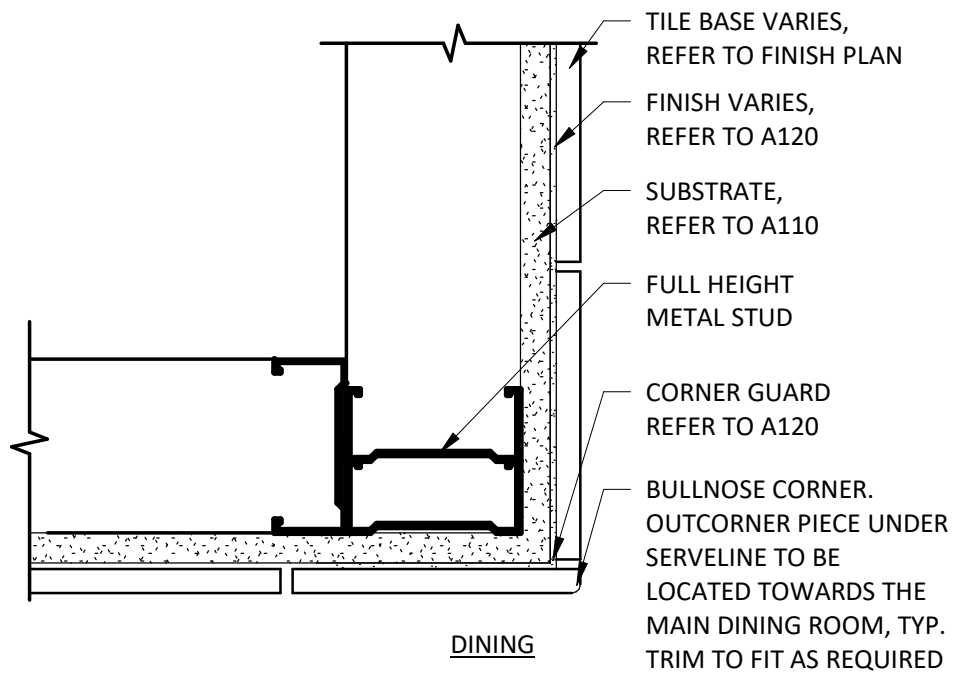


8
A802
TILE BASE - OUTSIDE CORNER (DINING)
3" = 1'-0"

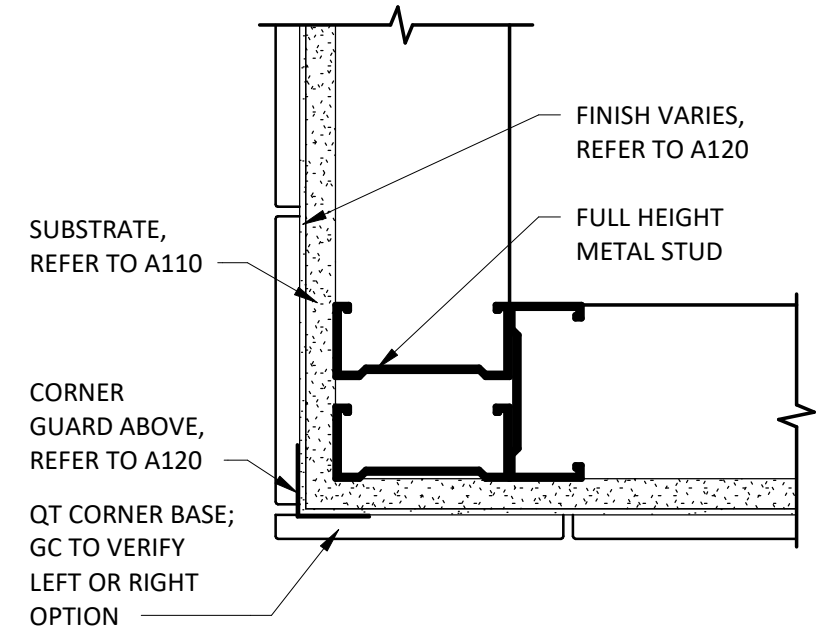


7
A802
QT BASE - OUTSIDE CORNER (KITCHEN)
3" = 1'-0"

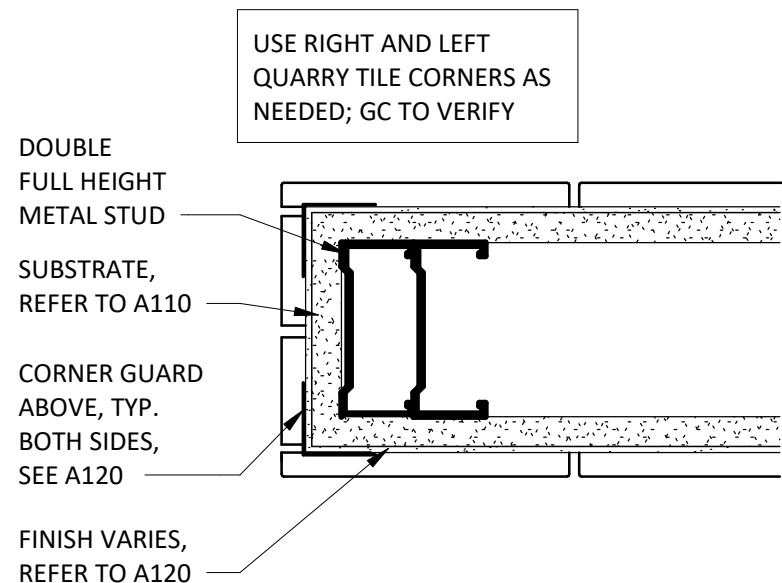


6
A802
QT BASE - ENDCAP
3" = 1'-0"

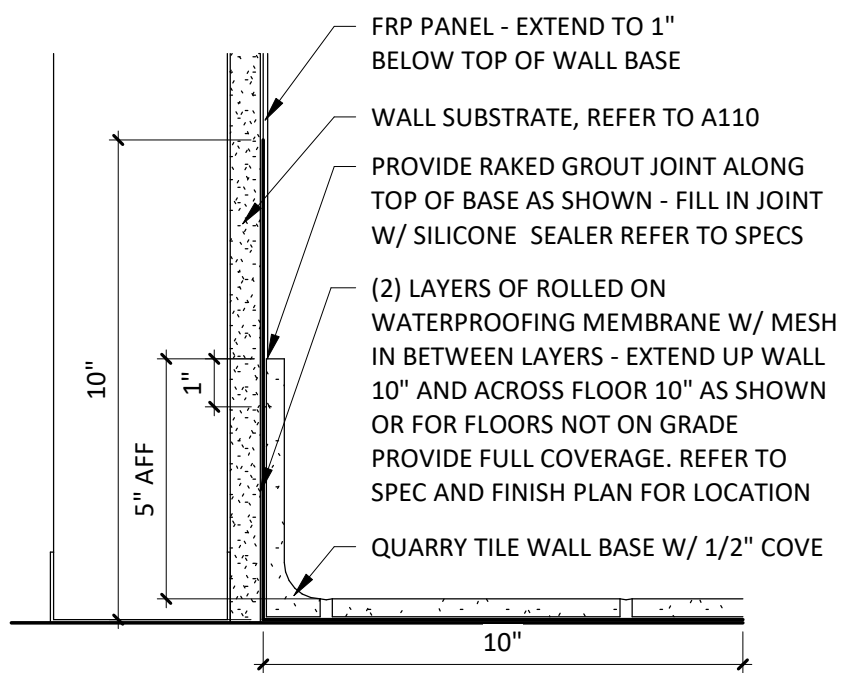


5
A802
QT BASE @ FRP
3" = 1'-0"

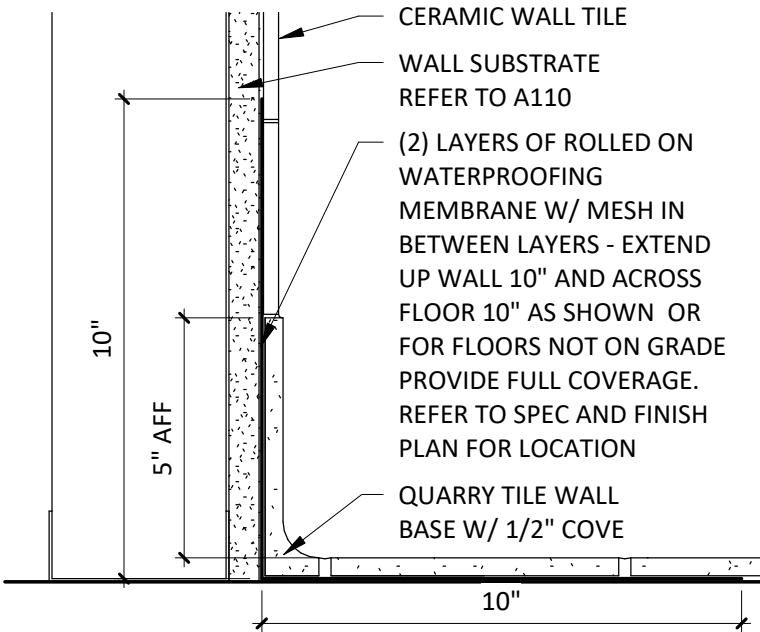

4
A802
QT BASE @ CERAMIC TILE
3" = 1'-0"

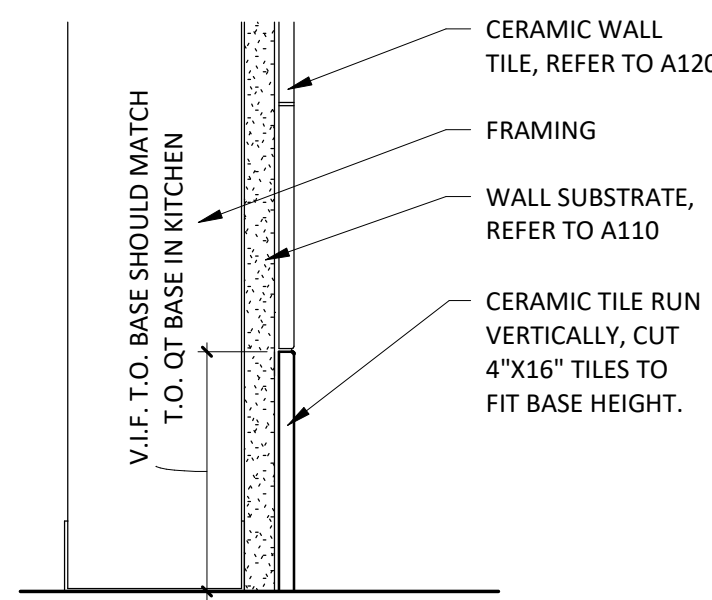

3
A802
CERAMIC TILE BASE
3" = 1'-0"

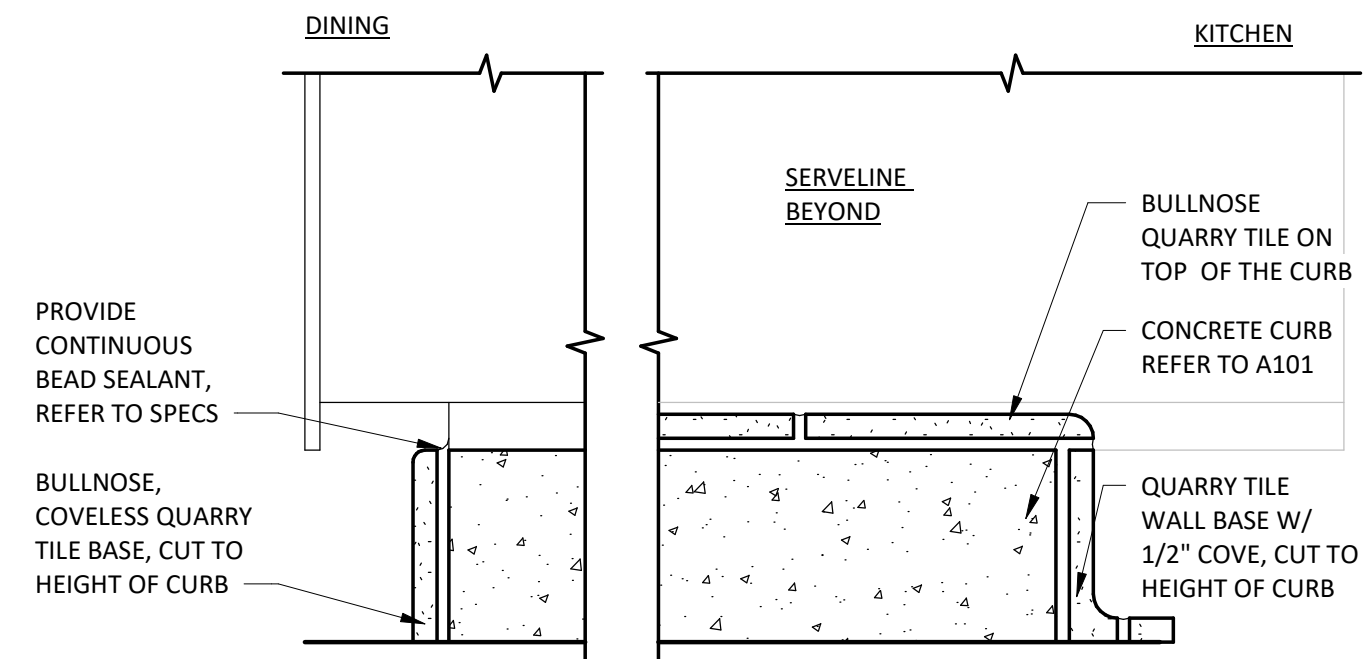

2
A802
QT @ CURB
3" = 1'-0"

1
A802
QT @ CURB
3" = 1'-0"

Consultant:

R/A

Red Architecture

589 W. NATIONWIDE BLVD. SUITE B
COLUMBUS, OHIO 43215 (614) 487-8770

FOR
CONSTRUCTION

COPYRIGHT 2023
THIS DRAWING IS AN INSTRUMENT OF SERVICE
AND AS SUCH REMAINS THE PROPERTY OF
CHIPOTLE MEXICAN GRILL, INC. PERMISSION FOR
USE OF THIS DOCUMENT IS LIMITED AND CAN BE
EXTENDED ONLY BY WRITTEN AGREEMENT WITH
CHIPOTLE MEXICAN GRILL, INC..



CHIPOTLE MEXICAN GRILL, INC.
PO BOX 182566
COLUMBUS, OH 43218-2566
TELEPHONE: 614.318.2400
INTERNET: WWW.CHIPOTLE.COM

STORE NO.: 4870
WALNUT HILLS
1202 E MCMILLAN STREET
CINCINNATI, OH 45206

Issue Record:

11/03/23 PERMIT SET
05/08/24 CONSTRUCTION SET

Revisions:

Drawn: JTH, PH
Checked: TC

Project No.

CMG1144

Contents:

TILE DETAILS

A802



Consultant:

R/A

Red/Architecture

589 W. NATIONWIDE BLVD. SUITE B
COLUMBUS, OHIO 43215 (614) 487-8770

COPYRIGHT 2023
THIS DRAWING IS AN INSTRUMENT OF SERVICE
AND AS SUCH REMAINS THE PROPERTY OF
CHIPOTLE MEXICAN GRILL, INC.. PERMISSION FOR
USE OF THIS DOCUMENT IS LIMITED AND CAN BE
EXTENDED ONLY BY WRITTEN AGREEMENT WITH
CHIPOTLE MEXICAN GRILL, INC..





CHIPOTLE MEXICAN GRILL, INC.
PO BOX 182566
COLUMBUS, OH 43218-2566
TELEPHONE: 614.318.2400
INTERNET: WWW.CHIPOTLE.COM

STORE NO.: 4870
WALNUT HILLS
1202 E MCMILLAN STREET
CINCINNATI, OH 45206

[illegible]


INTERIOR PERSPECTIVES

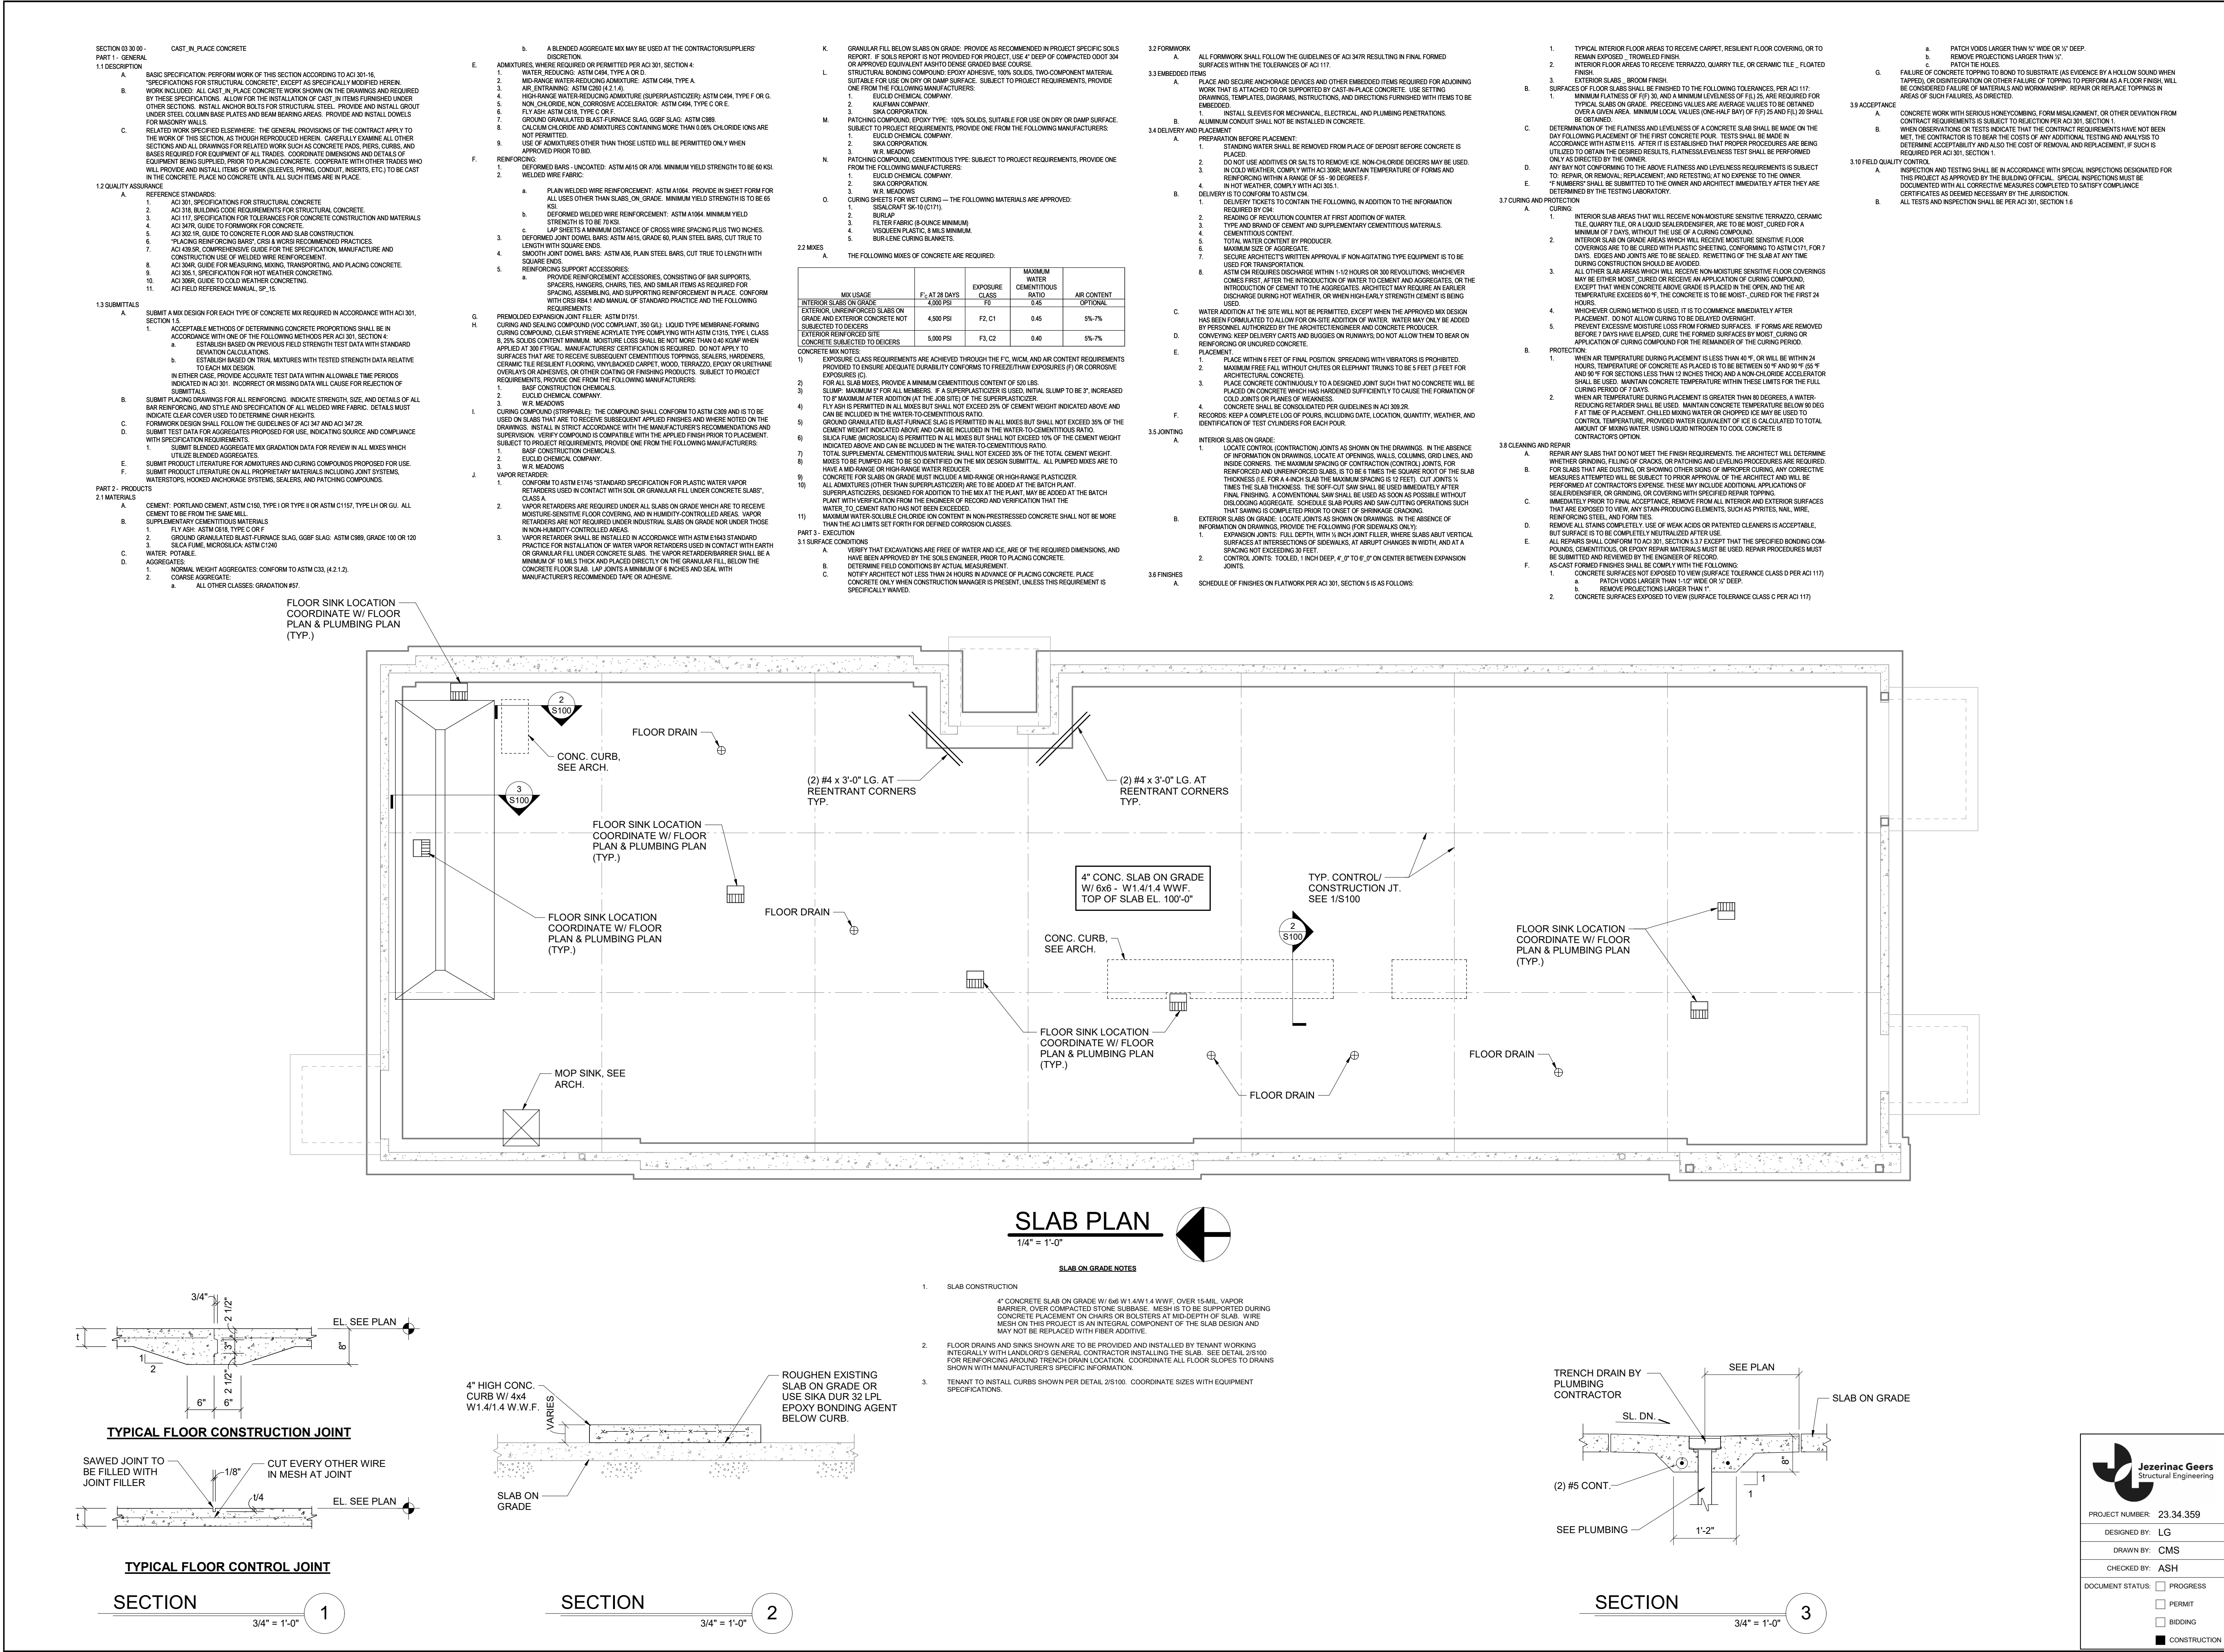

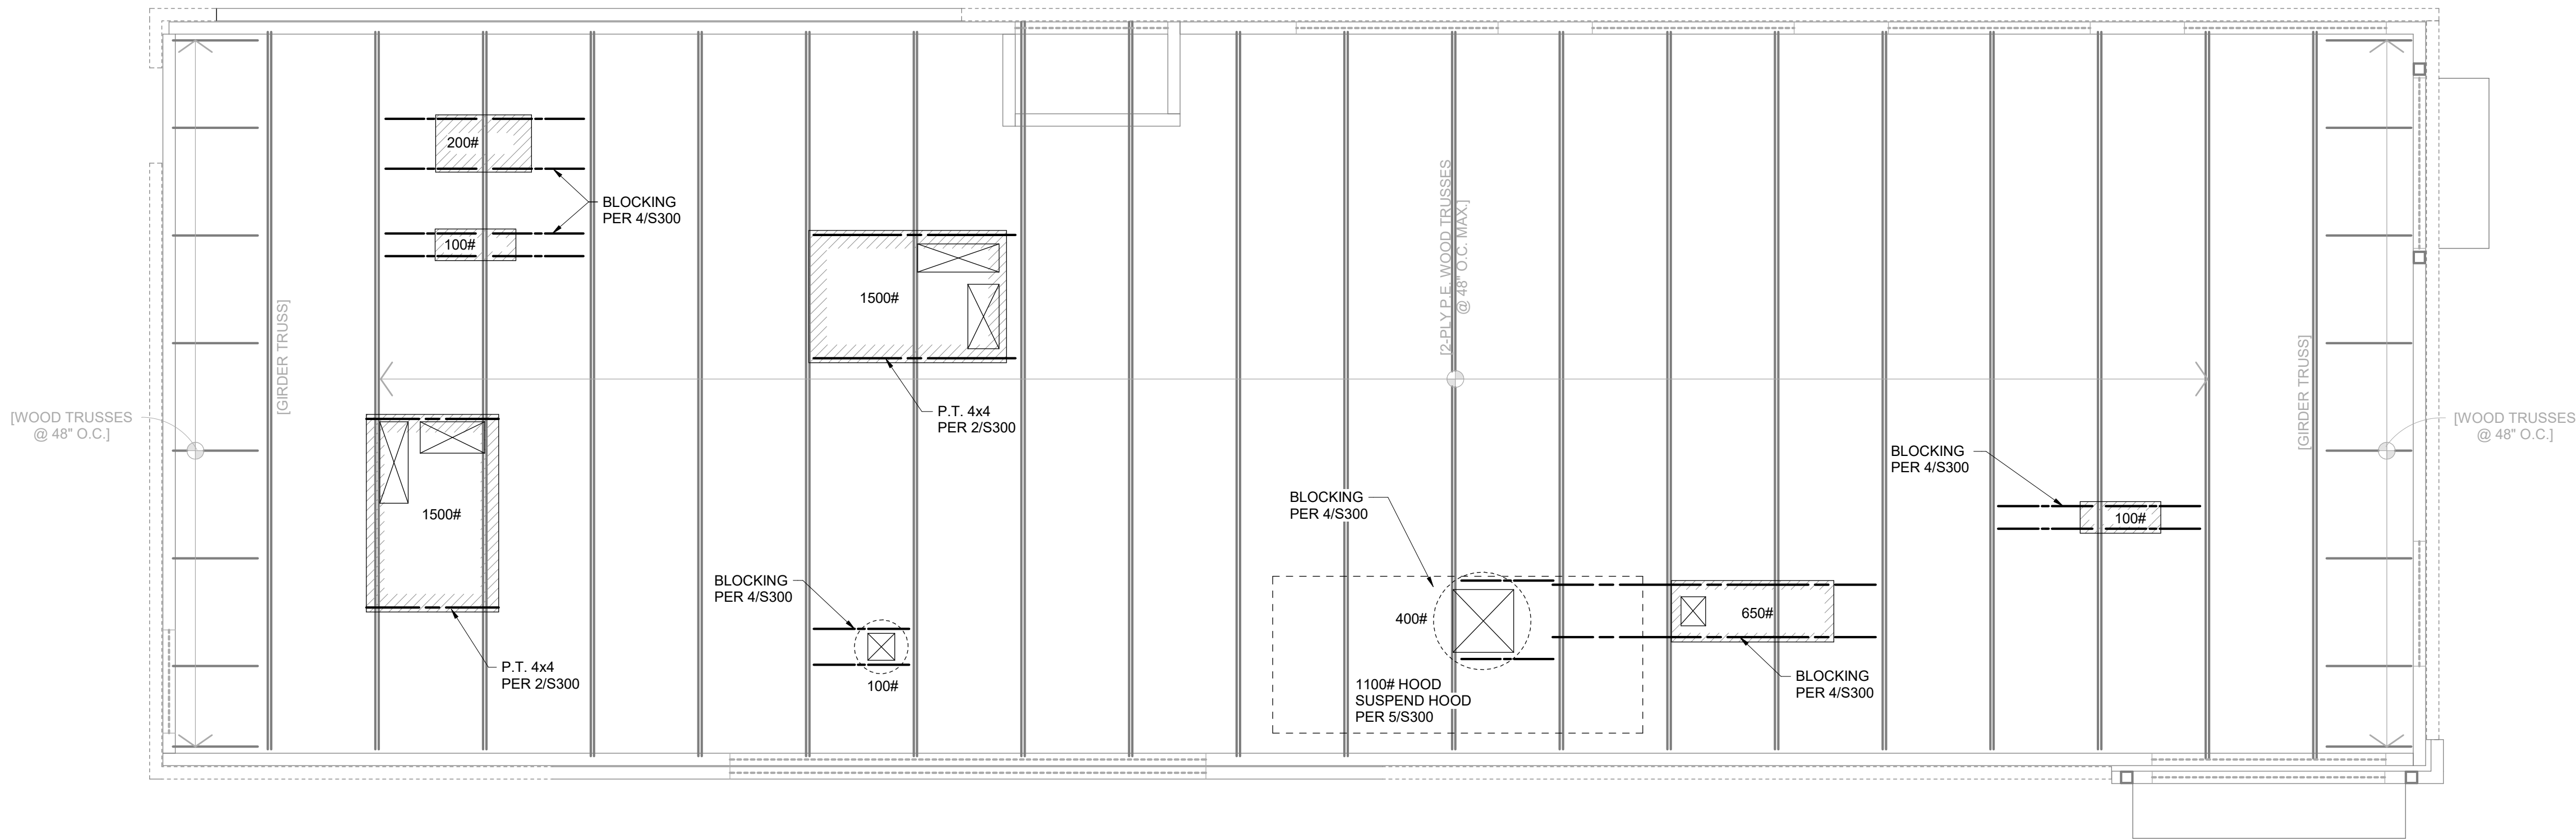

ROOF FRAMING PLAN

1/4" = 1'-0"

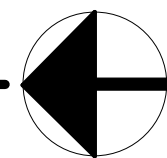

GENERAL STRUCTURAL NOTES

GENERAL

- THE STRUCTURE IS DESIGNED TO BE SELF-SUPPORTING AND STABLE AFTER THE CONSTRUCTION IS FULLY COMPLETED. IT IS SOLELY THE CONTRACTOR'S RESPONSIBILITY TO DETERMINE ERECTION PROCEDURE AND SEQUENCE AND TO ENSURE THE SAFETY OF THE BUILDING AND ITS COMPONENT PARTS DURING ERECTION. THIS INCLUDES THE ADDITION OF WHATEVER SHORING, SHEETING, TEMPORARY BRACING, GUYS, OR TIEDOWNS WHICH MIGHT BE NECESSARY. SUCH MATERIAL IS TO REMAIN THE CONTRACTOR'S PROPERTY AFTER COMPLETION OF THE PROJECT.
- IT IS SOLELY THE CONTRACTOR'S RESPONSIBILITY TO FOLLOW ALL APPLICABLE SAFETY CODES AND REGULATIONS DURING ALL PHASES OF CONSTRUCTION.
- MECHANICAL, EQUIPMENT LOADS, OPENINGS AND STRUCTURE IN ANY WAY RELATED TO MECHANICAL REQUIREMENTS ARE SHOWN FOR BIDDING PURPOSES ONLY. CONTRACTOR IS TO OBTAIN APPROVAL OF MECHANICAL AND OTHER TRADES BEFORE PROCEEDING WITH SUCH PORTION OF THE WORK. EXCESS COST RELATED TO VARIATION IN MECHANICAL REQUIREMENTS TO BE BORNE BY MECHANICAL CONTRACTOR.
- DO NOT SCALE THE DRAWINGS WHERE DIMENSIONS ARE NOT SPECIFICALLY GIVEN. SEE ARCHITECTURAL DRAWINGS FOR DIMENSIONS AND ELEVATIONS NOT SHOWN. COORDINATE ALL DIMENSIONS AND ELEVATIONS WITH THE ARCHITECTURAL DRAWINGS. ALL DIMENSIONS AND ELEVATIONS SHOWN ON THE STRUCTURAL DRAWINGS ARE NOT INTENDED TO ADJUST, NOR SUPERSEDE THOSE SHOWN ON THE ARCHITECTURAL DRAWINGS.
- FIELD VERIFY ALL DIMENSIONS AND CONDITIONS PRIOR TO CONSTRUCTION. NOTIFY THE ARCHITECT IMMEDIATELY WHERE CONFLICTS EXIST WITHIN THE DRAWINGS OR BETWEEN THE DRAWINGS AND FIELD CONDITIONS.
- THROUGHOUT THESE PLANS, THE TERM "PROVIDE" IS DEFINED AS "SUPPLY AND INSTALL".
- SHOULD ANY OF THE DETAILED INSTRUCTIONS SHOWN ON THE PLANS CONFLICT WITH THE GENERAL STRUCTURAL NOTES, THE SPECIFICATIONS OR WITH EACH OTHER, THE STRICTEST PROVISION WILL GOVERN.
- CODE INFORMATION
 - GOVERNING CODE: 2017 OHIO BUILDING CODE
 - BUILDING RISK CATEGORY: CATEGORY II
 - ROOF LIVE LOADS
 - ORDINARY FLAT, PITCHED, AND CURVED ROOFS: 20 PSF
 - SNOW LOADS
 - GROUND SNOW LOAD (Pg): 20 PSF
 - FLAT ROOF SNOW LOAD (P_f): 20 PSF
 - SNOW EXPOSURE FACTOR (Ce): 1.0
 - SNOW LOAD IMPORTANCE FACTOR (I_s): 1.0
 - THERMAL FACTOR (C_t): 1.0
 - SNOW DRIFTING: SEE PLAN
 - WIND LOADS
 - WIND IMPORTANCE FACTOR: 1.0
 - BASIC ULTIMATE WIND SPEED (V_{ult}): 115 MPH
 - BASIC ALLOWABLE WIND SPEED (V_{all}): 90 MPH
 - SITE EXPOSURE CATEGORY: C
 - INTERNAL PRESSURE COEFFICIENT: +/- 0.18
 - SEISMIC LOADS (NON-STRUCTURAL COMPONENTS)
 - COMPONENT IMPORTANCE FACTOR, I_p: 1.0
 - COMPONENT RESPONSE MODIFICATION FACTOR, R_p: HVAC EQUIPMENT: R_p = 6.0
 - COMPONENT AMPLIFICATION FACTOR, A_p: HVAC EQUIPMENT: A_p = 2.5
 - DESIGN SPECTRAL RESPONSE ACCELERATION (S_{ds}): 0.50g
 - SPECIAL LOADS
 - INTERIOR WALLS & PARTITIONS: 5 PSF HORIZONTAL
 - HANDRAIL LOADS (ANY DIRECTION): 50 PLF/200# CONC.
- EXISTING ROOF CONSTRUCTION:
 - 1-1/2" WIDE RIB METAL DECK OVER STEEL JOIST & BEAMS
 - RATED WOOD SHEATHING ON PRE-ENGINEERED WOOD TRUSSES OR 2x4 FRAMING.
- INDICATES SNOW DRIFT ROOF LOADING. JOISTS HAVE BEEN SIZED FOR THE LOAD SHOWN UNLESS NOTED OR SCHEDULED OTHERWISE. WOOD TRUSSES ARE TO BE DESIGNED TO ACCOMMODATE ADDITIONAL LOADINGS. PRE-ENGINEERED METAL BUILDING STRUCTURES IS TO BE DESIGNED TO ACCOMMODATE ADDITIONAL LOADING.
- INDICATES MECHANICAL LOAD SUPPORTED ON ROOF. COORDINATE FINAL SIZE, WEIGHT, LOCATION, AND OPENING REQUIREMENTS WITH MECHANICAL CONTRACTOR. PROVIDE A ROOF FRAME AT UNIT CURBS SIMILAR TO SECTIONS 16300 AND 215500 AND REINFORCE JOISTS AT CONCENTRATED LOAD SUPPORT LOCATIONS PER SECTION 46300. PROVIDE RTU CURB TO MATCH THE SLOP OF THE ROOF STRUCTURE (FIELD VERIFY ROOF SLOPE) TOP SURFACE SHALL BE LEVEL FOR MOUNTING OF EQUIPMENT TO ENSURE PROPER DRAINAGE OF EQUIPMENT.
- INDICATES ROOF OPENING. DETERMINE EXACT SIZE AND LOCATION FROM ARCHITECTURAL AND MECHANICAL DRAWINGS. PROVIDE A FRAME PER SECTION 63300 AT ALL OPENINGS GREATER THAN 4" PERPENDICULAR TO THE DECK SPAN.

Consultant:



Jezerinac Geers & Associates, Inc.
5640 Frantz Road, Dublin, OH 43017
614.766.0066, fax 614.766.1223
www.jgaeng.com

FOR
CONSTRUCTION

COPYRIGHT 2023
THIS DRAWING IS AN INSTRUMENT OF SERVICE
AND AS SUCH REMAINS THE PROPERTY OF
CHIPOTLE MEXICAN GRILL, INC.. PERMISSION FOR
USE OF THIS DOCUMENT IS LIMITED AND CAN BE
EXTENDED ONLY BY WRITTEN AGREEMENT WITH
CHIPOTLE MEXICAN GRILL, INC..



CHIPOTLE MEXICAN GRILL, INC.
PO BOX 182566
COLUMBUS, OH 43218-2566
TELEPHONE: 614.318.2400
INTERNET: WWW.CHIPOTLE.COM

STORE NO.: 4870
WALNUT HILLS, OH
1202 E MCMILLAN STREET
CINCINNATI, OH 45206

Issue Record:

11/03/23	PERMIT SET
05/08/24	CONSTRUCTION SET

Revisions:

Drawn: Checked:

CMS LG

Project No.

23.34.359

Contents:

ROOF FRAMING
PLAN

S110



GENERAL NOTES APPLY TO HVAC SHEETS.

WORK SHALL COMPLY WITH STATE AND LOCAL CODE REQUIREMENTS AS APPROVED AND AMENDED BY THE AUTHORITY HAVING JURISDICTION, INCLUDING APPLICABLE SECTIONS OF NFPA, THE MECHANICAL CODE, AND ANY INTERIM AMENDMENTS AT THE TIME OF THE PROPOSAL. PURCHASE PERMITS ASSOCIATED WITH THE WORK. OBTAIN INSPECTIONS REQUIRED BY CODE. SEE ARCHITECTURAL SHEETS FOR THE PREVAILING CODES.

CONTRACTOR AND SUBCONTRACTORS SHALL REVIEW A COMPLETE SET OF THE CONSTRUCTION DOCUMENTS.

COORDINATE WORK WITH THE WORK OF OTHER TRADES, EQUIPMENT FURNISHED BY OTHERS, REQUIREMENTS OF THE OWNER, AND OF THE EXISTING CONDITIONS AT THE PROJECT SITE.

DRAWINGS FOR THE MECHANICAL WORK ARE DIAGRAMMATIC, SHOWING THE GENERAL LOCATION, TYPE, LAYOUT, AND EQUIPMENT REQUIRED. THE DRAWING SHALL NOT BE SCALED FOR EXACT MEASUREMENTS, REFER TO ARCHITECTURAL DRAWINGS FOR DIMENSIONS. REFER TO MANUFACTURER'S STANDARD INSTALLATION DRAWINGS FOR EQUIPMENT CONNECTIONS AND INSTALLATION REQUIREMENTS. PROVIDE DUCTWORK, CONNECTIONS, OFFSETS, ACCESSORIES, AND MATERIALS NECESSARY FOR A COMPLETE SYSTEM.

DUCT DIMENSIONS ON PLANS INDICATE DIMENSIONS OF INTERNAL FREE AREA.

PERFORATED CEILING DIFFUSERS SHALL BE 4-WAY UNLESS NOTED OTHERWISE.

COORDINATE ROOF WORK WITH THE OWNER'S CONSTRUCTION MANAGER PRIOR TO CONSTRUCTION.

UNLESS NOTED OTHERWISE RECTANGULAR DUCT ELBOWS GREATER THAN 45° SHALL BE MITERED ELBOWS WITH DOUBLE-THICKNESS TURNING VANES AND RECTANGULAR DUCT ELBOWS 45° OR LESS SHALL BE RADIUSIED ELBOWS WITH AN INSIDE RADIUS OF AT LEAST 1/2 THE WIDTH OF THE DUCT.

REPLACE AIR FILTERS WITH NEW, CLEAN MERV 8 AIR FILTERS AT TURNOVER.

THE TERM "FURNISH" MEANS SUPPLY AND DELIVER TO THE PROJECT SITE, READY FOR UNLOADING, UNPACKING, ASSEMBLY, INSTALLATION, AND SIMILAR OPERATIONS. THE TERM "INSTALL" DESCRIBES THE OPERATIONS AT THE PROJECT SITE INCLUDING THE ACTUAL UNLOADING, UNPACKING, ASSEMBLY, ERECTING, PLACING, ANCHORING, APPLYING, WORKING TO DIMENSION, FINISHING, CURING, PROTECTING, CLEANING, AND SIMILAR OPERATIONS. THE TERM "PROVIDE" MEANS TO FURNISH AND INSTALL, COMPLETE AND READY FOR THE INTENDED USE.

PROVIDE LABELING CALLED FOR IN THE HVAC DRAWINGS USING ENGRAVED PHENOLIC PLATES.

PROVIDE P3000 12 GA. UNISTRUT WITH PG FINISH FOR DUCT SUPPORTS AND OTHER UNISTRUT IN AREAS EXPOSED TO VIEW. SLOTTED UNISTRUT AND OTHER UNISTRUT WITH HOLES IS NOT ACCEPTABLE.



NATIONAL
ENGINEERING

FOR CONSTRUCTION

The logo for Chipotle Mexican Grill, featuring a circular emblem with a stylized chili pepper in the center. The word "CHIPOTLE" is arched over the top, and "MEXICAN GRILL" is arched along the bottom.

STORE NO.: 4870
WALNUT HILLS, OH
1202 E. MCMILLAN
CINCINNATI, OH 45206

M010

CATEGORY	APPLICATION	ALLOWABLE MATERIAL
DUCT	EXPOSED SUPPLY	RECT. LINED OR ROUND AS SHOWN, NO EXPOSED DUCT-SEALING MASTIC
	EXPOSED RETURN	RECTANGULAR, NO EXPOSED DUCT-SEALING MASTIC
	EXPOSED GEN. EXHAUST	RECTANGULAR OR ROUND AS SHOWN, NO EXPOSED DUCT-SEALING MASTIC
	CONCEALED, SUPPLY	RECT. OR ROUND AS SHOWN, LINED OR INSULATED
	CONCEALED, RETURN	RECT. OR ROUND AS SHOWN, LINED OR INSULATED
	CONCEALED, GEN. EXHAUST	RECT. OR ROUND AS SHOWN
	CONCEALED, TYPE I HOOD EXHAUST	RECTANGULAR 16 GA. BLACK IRON W/ WRAP OR UL 1978 FACTORY-MANUFACTURED DUCT W/ WRAP (SUBMIT SHOP DRAWINGS FOR FACTORY-MANUFACTURED DUCT PRIOR TO ORDERING FOR APPROVAL)

AFB	ABOVE FINISHED FLOOR
AFG	ABOVE FINISHED GRADE
CD	CEILING DIFFUSER
CU	CONDENSING UNIT
(E)	EXISTING
EF	EXHAUST FAN
ER	EXHAUST REGISTER
EXT'G	EXISTING
HD	HOOD
MUA	MAKEUP AIR UNIT
OBD	BLADE DAMPER
RG	RETURN GRILLE
RTU	ROOFTOP UNIT
SR	SUPPLY REGISTER
VSC	VARIABLE SPEED CONTROL
COZAS	TENANT'S CO2 ALARM SUPPLIER
GC	GENERAL CONTRACTOR
HES	TENANT'S HVAC EQUIPMENT SUPPLIER
HS	TENANT'S HOOD SUPPLIER
KE\$	TENANT'S KITCHEN EQUIPMENT SUPPLIER
TAB	TENANT'S TEST AND BALANCE VENDOR
TC	TENANT'S CABLING CONTRACTOR
TD	TENANT'S DUCT CLEANER
TEMS	TENANT'S ENERGY MANAGEMENT SYSTEM SUPPLIER
TL\$	TENANT'S LIGHT/LAMP SUPPLIER
TMB	TENANT'S MENU BOARD SUPPLIER
TMS	TENANT'S MILLWORK SUPPLIER
TP	TENANT'S PHONE SUPPLIER
TPS	TENANT'S PANELBOARD SUPPLIER
TRS	TENANT'S RAILING SUPPLIER
T\$V	TENANT'S SIGN VENDOR
TUV	TENANT'S UV SANITIZER SUPPLIER
WC\$	TENANT'S WALK-IN COOLER SUPPLIER
WH\$	TENANT'S WATER HEATER SUPPLIER


	CEILING DIFFUSER
	CEILING-MOUNTED RETURN OR EXHAUST REGISTER
	SUPPLY REGISTER
	RETURN GRILLE
	FLEXIBLE DUCT
	MITERED CORNER WITH TURNING VANES
	DUCTWORK INTERNAL FREE DIMENSIONS (WIDTH/HEIGHT)
	RECTANGULAR TO ROUND DUCT TRANSITION
	DUCT-MOUNTED SMOKE DETECTOR
	MOTOR-OPERATED DAMPER
	MANUAL VOLUME DAMPER
	GREASE DUCT CLEANOUT
	MITERED CORNER WITHOUT TURNING VANES
	GRIDPOINT THERMOSTAT
	GRIDPOINT ZONE SENSOR MODULE
	GRIDPOINT SUPPLY PROBE
	PLAN NOTE: SEE PLAN NOTES LISTED ON THE SAME SHEET FOR NOTE MEANING
	CONNECT TO EXISTING
	EQUIPMENT TAG: SEE EQUIPMENT SCHEDULE ON SHEET M600 FOR EQUIPMENT INFORMATION
	AUDIO/VISUAL REMOTE SMOKE DETECTOR ANNUNCIATOR WITH REMOTE KEY OPERATED RESET
	GRILL, REGISTER, OR DIFFUSER TAG: TAG NECK SIZE AIRFLOW [CFM]

HVAC PLAN NOTES


- SEE ARCHITECTURAL REFLECTED CEILING PLAN FOR CEILING MOUNTED EQUIPMENT LOCATION. TYPICAL.
- PAINT DUCTWORK VISIBLE THROUGH DINING ROOM SUPPLY REGISTERS AND RETURN GRILL BLACK. TYPICAL.
- PROVIDE SUPPLY DIFFUSER CONNECTION TO SUPPLY SYSTEM PER DETAIL 1/M700. TYPICAL.
- 26/14 DUCT UP FOR TRANSITION TO RTU-1 RETURN CONNECTION IN ROOF CURB. RTU-1 SHALL HAVE A GC PROVIDED SMOKE DETECTOR MOUNTED IN THE RETURN AIR STREAM. INTERLOCK SMOKE DETECTOR TO RTU-1 OPERATION.
- 30/16 DUCT UP FOR TRANSITION TO RTU-2 RETURN CONNECTION IN ROOF CURB. RTU-2 SHALL HAVE A GC PROVIDED SMOKE DETECTOR MOUNTED IN THE RETURN AIR STREAM. INTERLOCK SMOKE DETECTOR TO RTU-2 OPERATION.
- 28/14 DUCT UP FROM BUILDING SUPPLY THROUGH ROOF. TRANSITION TO RTU-1 SUPPLY CONNECTION IN ROOF CURB.
- 26/18 DUCT UP FROM BUILDING SUPPLY TO RTU-2 SUPPLY CONNECTION. TRANSITION IN ROOF CURB.
- 14/14 DUCT UP THROUGH ROOF. TRANSITION TO MAU-1 SUPPLY CONNECTION IN ROOF CURB.
- 24/10 DUCT UP FROM HOOD THROUGH ROOF TO EF-1 COMPLIANT WITH NFPA 96. PROVIDE RADIUSSED ELBOWS WITH AN INSIDE RADIUS OF 0.5W AT ELBOWS IN GREASE DUCT.
- 8/6 DUCT UP THROUGH ROOF TO EF-2.
- 28/6 DUCT DOWN TO MAKEUP AIR PSP DUCT CONNECTION. TRANSITION TO SUPPLY PLENUM OPENING SIZE. TYPICAL. CAP UNUSED DUCT CONNECTIONS.
- 28/10 DUCT DOWN TO AC PSP DUCT CONNECTION. TRANSITION TO SUPPLY PLENUM OPENING SIZE. TYPICAL. CAP UNUSED DUCT CONNECTIONS.
- INSTALL GRIDPOINT THERMOSTATS FURNISHED BY TEMS FOR RTU-1 AND RTU-2 AT THIS LOCATION AT 48" AFF. COORDINATE WITH ELECTRICAL SWITCHING IN THIS AREA. PROVIDE WIRING AS SHOWN IN DETAIL 8/E710.
- INSTALL GRIDPOINT ZONE SENSOR MODULE FURNISHED BY TEMS FOR RTU-1 AT THIS LOCATION 60" AFF DIRECTLY TO WALL (NO JUNCTION BOX). COORDINATE LOCATION WITH EQUIPMENT. PROVIDE WIRING AS SHOWN IN DETAIL 8/E710.
- INSTALL GRIDPOINT ZONE SENSOR MODULE FURNISHED BY TEMS FOR RTU-2 AT THIS LOCATION 66" AFF DIRECTLY TO WALL (NO JUNCTION BOX). COORDINATE LOCATION WITH EQUIPMENT. PROVIDE WIRING AS SHOWN IN DETAIL 8/E710.
- INSTALL GRIDPOINT SUPPLY PROBE FURNISHED BY TEMS FOR RTU-1 IN THE SUPPLY DUCTWORK UPSTREAM FROM THE FIRST BRANCH CONNECTION. PROVIDE WIRING AS SHOWN IN DETAIL 8/E710.
- INSTALL GRIDPOINT SUPPLY PROBE FURNISHED BY TEMS FOR RTU-2 IN THE SUPPLY DUCTWORK UPSTREAM FROM THE FIRST BRANCH CONNECTION. PROVIDE WIRING AS SHOWN IN DETAIL 8/E710.
- INSTALL REMOTE TEMPERATURE SENSOR FOR HOOD HD-1 AT THIS LOCATION 60" AFF. COORDINATE LOCATION WITH EQUIPMENT. PROVIDE (2) #18 G. THERMISTOR CABLE FROM TEMPERATURE SENSOR TO HOOD CONTROL PANEL.

HVAC PLAN NOTES


- INSTALL KITCHEN HOOD, HD-1. SUPPORT HOOD PER MANUFACTURER'S INSTALLATION INSTRUCTIONS AND AS DETAILED IN THE ARCHITECTURAL AND STRUCTURAL DRAWINGS. INSTALL HOOD ACCORDING TO THE REQUIREMENTS OF ITS LISTING, IN COMPLIANCE WITH NFPA 96, THE BUILDING CODE, AND AUTHORITIES HAVING JURISDICTION. HOOD SHALL HAVE AN INTEGRAL DUCT COLLAR TEMPERATURE SENSOR TO AUTOMATICALLY ENERGIZE THE EXHAUST AND MAKEUP AIR FANS IF COOKING TEMPERATURES ARE DETECTED. EXHAUST DUCT SYSTEM TO BE WELDED OR FACTORY-MANUFACTURED WATER AND AIR TIGHT. INSTALL CLEANOUTS PER CODE AND AS SHOWN. INSTALL HOOD PER DETAILS 2, 4, AND 9/M700. CHIPOTLE WILL PROVIDE AN INDEPENDENT TESTING AGENCY FOR TESTING THE INTEGRITY OF THE GREASE DUCT SYSTEM.
- INSTALL REMOTE CONDENSING UNIT FOR WALK-IN COOLER ON ROOF AS DETAILED IN THE ARCHITECTURAL AND STRUCTURAL DRAWINGS. INSTALL REFRIGERANT LINE SET, THERMOSTATIC EXPANSION VALVE, SOLENOID VALVE, TEMPERATURE CONTROL, SIGHT GLASS, FILTER DRIER, PRESSURE CONTROL, LOW AMBIENT CONTROLS, AND WEATHERPROOF HOUSING. TRAP AND SLOPE REFRIGERANT LINES PER MANUFACTURER'S RECOMMENDATIONS. INSTALLATION SHALL COMPLY WITH ASHRAE/ANSI STANDARD 15. INSTALL THE REFRIGERANT LINE SET UNDER THE ROOF DECK TO WITHIN 3' OF THE CONDENSING UNIT. CUT 2-1/2" HOLE IN WALK-IN COOLER ROOF FOR REFRIGERANT LINE SET AND SEAL PER THE COOLER MANUFACTURER'S INSTALLATION INSTRUCTIONS AFTER LINE SET IS INSTALLED.
- INSTALL REMOTE CONDENSER FOR ICE MACHINE ON ROOF AS DETAILED IN THE ARCHITECTURAL AND STRUCTURAL DRAWINGS. INSTALL REFRIGERANT LINE SET, THERMOSTATIC EXPANSION VALVE, SOLENOID VALVE, TEMPERATURE CONTROL, SIGHT GLASS, FILTER DRIER, PRESSURE CONTROL, LOW AMBIENT CONTROLS, AND WEATHERPROOF HOUSING. TRAP AND SLOPE REFRIGERANT LINES PER MANUFACTURER'S RECOMMENDATIONS. SEAL PIPING PENETRATIONS THROUGH ROOF. INSTALLATION SHALL COMPLY WITH ASHRAE/ANSI STANDARD 15. INSTALL THE REFRIGERANT LINE SET UNDER THE ROOF DECK TO WITHIN 3' OF THE REMOTE CONDENSER. IF REFRIGERANT PIPING TO ICE MAKER IS EXPOSED TO PUBLIC VIEW CONCEAL WITHIN A STAINLESS STEEL SHROUD AS SHOWN IN THE ARCHITECTURAL DRAWINGS.
- INSTALL ROOFTOP EQUIPMENT PER MANUFACTURER'S INSTALLATION INSTRUCTIONS AND AS DETAILED IN THE ARCHITECTURAL AND STRUCTURAL DRAWINGS.
- INSTALL EXHAUST FAN EF-1 PER DETAIL 5/M700 AND AS DETAILED IN THE ARCHITECTURAL AND STRUCTURAL DRAWINGS. INSTALL GREASE VIROGUARD SYSTEM FURNISHED BY CHIPOTLE ON EXHAUST FAN, EF-1.
- PROVIDE AUDIO/VISUAL REMOTE SMOKE DETECTOR ANNUNCIATOR WITH REMOTE KEY OPERATED RESET. WIRE A UNIT BACK TO EACH SMOKE DETECTOR. MOUNT UNIT 60" AFF. TYPICAL.
- INSTALL REME HALO AIR PURIFIER FURNISHED BY TUV IN RTU PER DETAIL 6/M700. SEE ELECTRICAL DRAWINGS FOR POWER CONNECTION INFORMATION. INSTALL UV WARNING STICKERS ON FACE OF ENCLOSURE PER DETAIL AND ON ANY RTU ACCESS DOOR(S) THROUGH WHICH THE REME HALO WOULD BE VISIBLE IF OPENED.
- MAINTAIN 10' CLEARANCE BETWEEN WATER HEATER FLUE TERMINATION AND OUTSIDE AIR INTAKES. MAINTAIN 10' CLEARANCE BETWEEN WATER HEATER COMBUSTION AIR INTAKE AND EXHAUST FAN EF-1 DISCHARGE. SEE PLUMBING DRAWINGS FOR MORE INFORMATION ON WATER HEATER FLUE AND COMBUSTION AIR TERMINATIONS.
- ADJUST SUPPLY REGISTERS SO THAT SUPPLY AIR HITS WALL ON OPPOSITE SIDE OF ROOM AT APPROXIMATELY 7' AFF WITH NO DRAFTS FELT IN THE DINING ROOM.

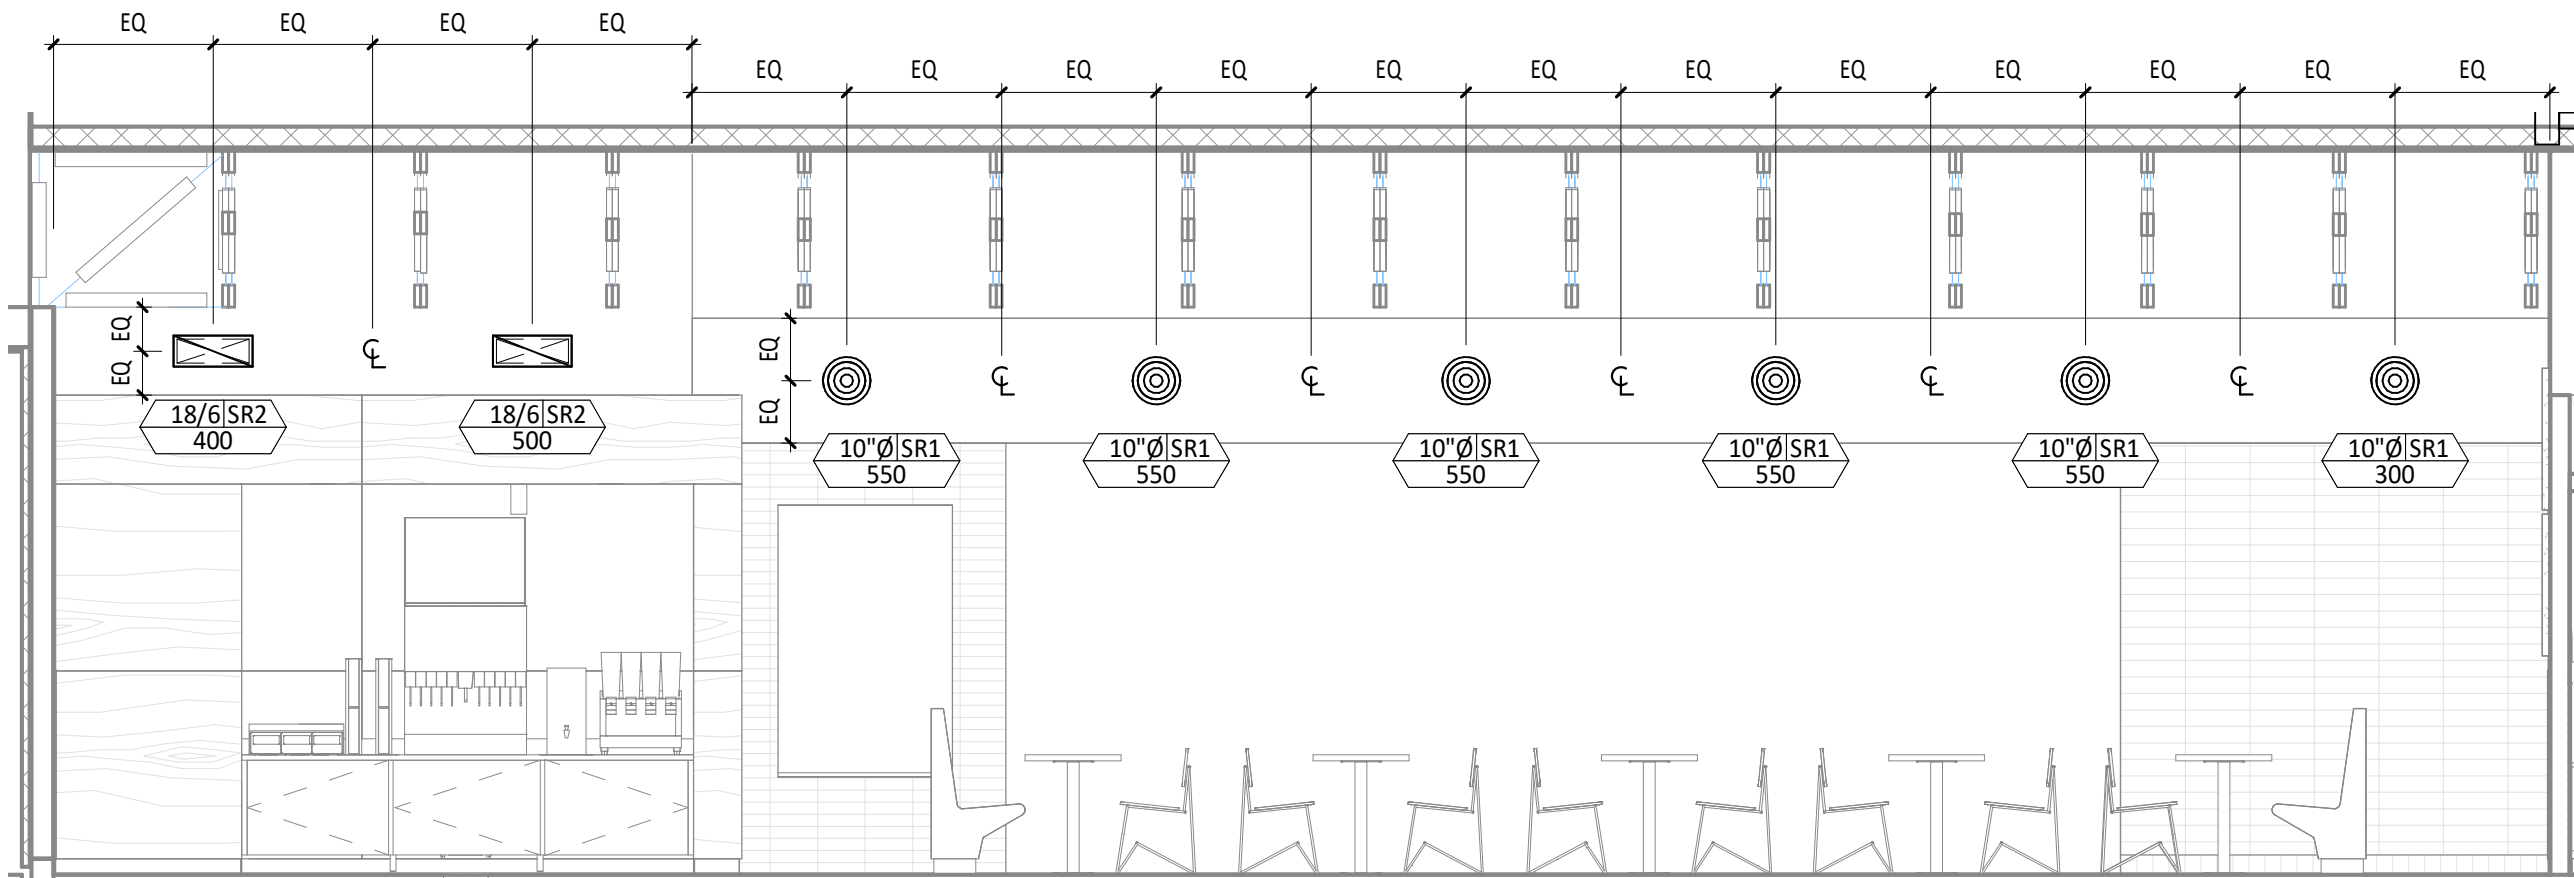

3 M100
1/4" = 1'-0"

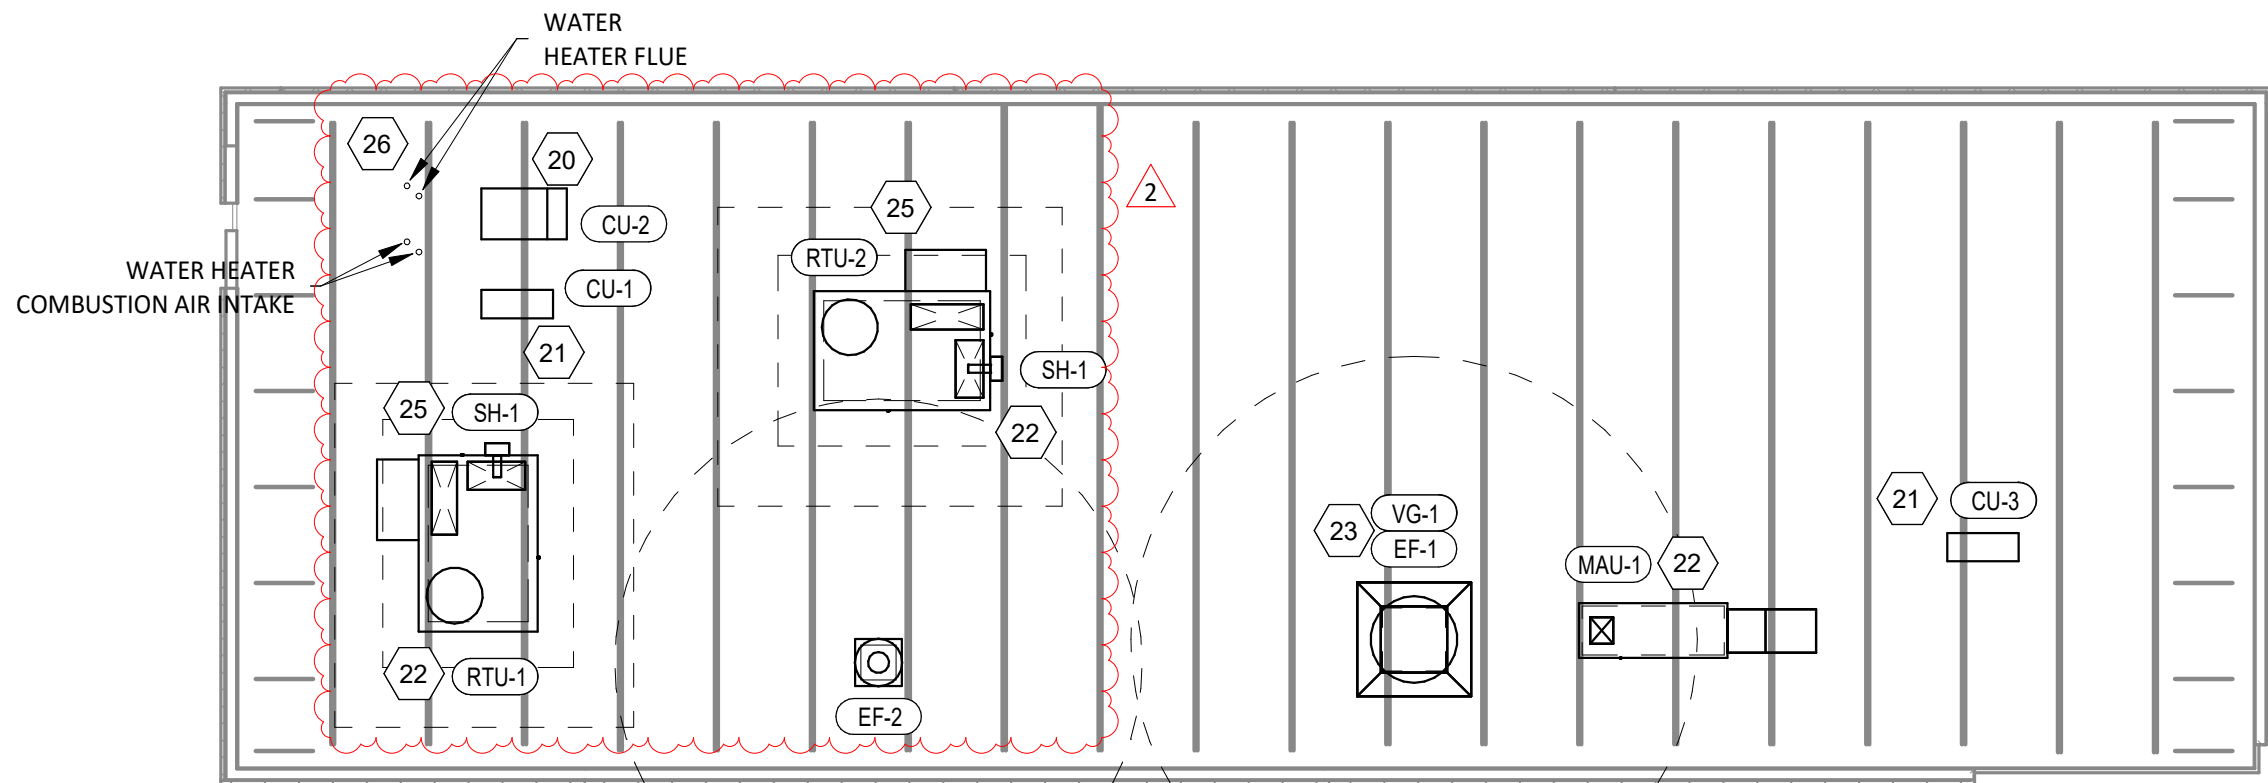

2 M100
1/8" = 1'-0"

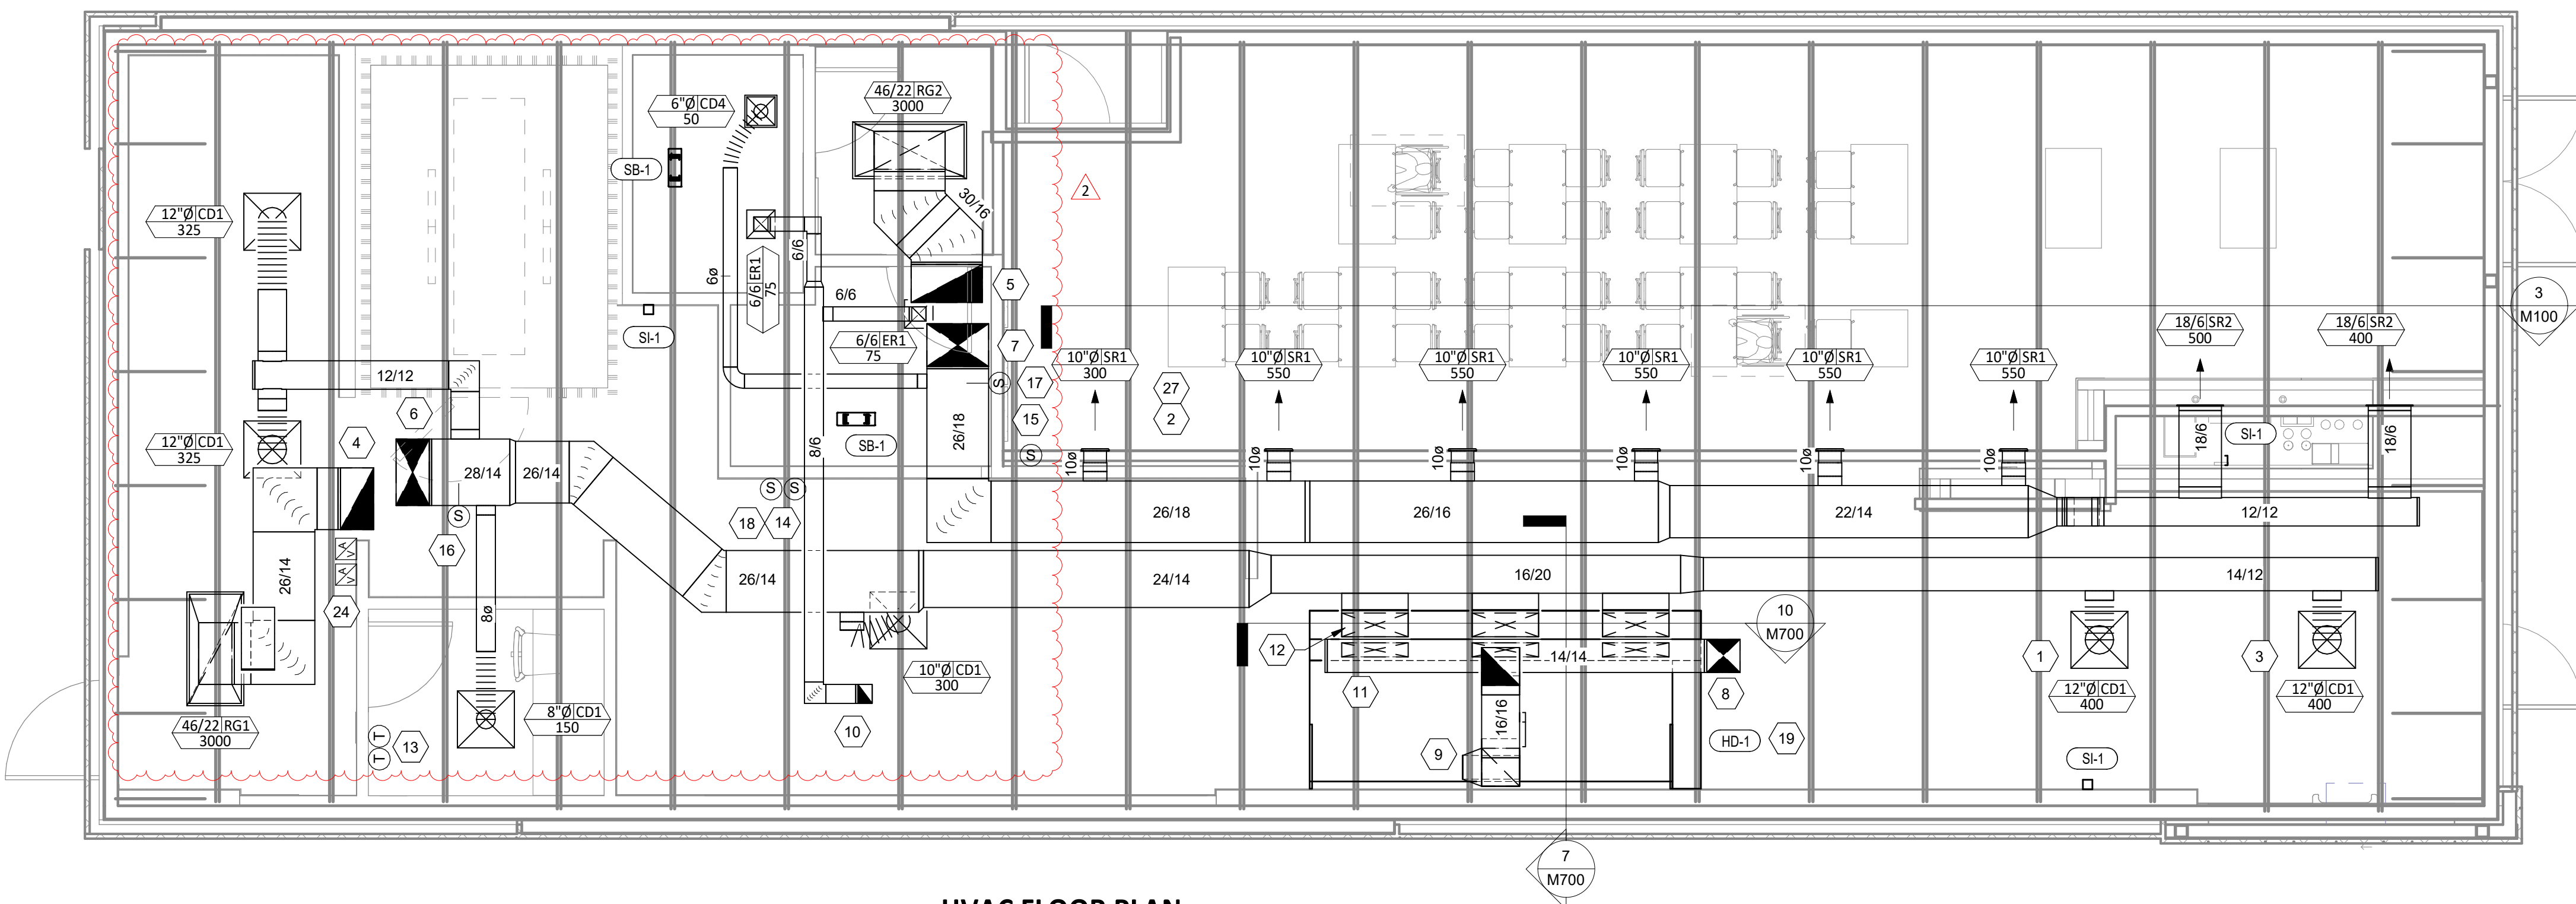

1 M100
1/4" = 1'-0"

Consultant:



4635 Trueman Blvd, Suite 250
Hilliard, Ohio 43026
Phone: (614) 751-9610
Fax: (614) 552-5240
Contact: Cliff Kigar
(614) 328-2033
ckigar@nationalengineering.com

FOR CONSTRUCTION

COPYRIGHT 2024
THIS DRAWING IS AN INSTRUMENT OF SERVICE
AND AS SUCH REMAINS THE PROPERTY OF
CHIPOTLE MEXICAN GRILL, INC.. PERMISSION FOR
USE OF THIS DOCUMENT IS LIMITED AND CAN BE
EXTENDED ONLY BY WRITTEN AGREEMENT WITH
CHIPOTLE MEXICAN GRILL, INC..



CHIPOTLE MEXICAN GRILL, INC.
PO BOX 182566
COLUMBUS, OH 43218-2566
TELEPHONE: (614) 318-2400
INTERNET: WWW.CHIPOTLE.COM

STORE NO.: 4870
WALNUT HILLS, OH
1202 E. MCMILLAN
CINCINNATI, OH 45206

Issue Record:
11/03/2023 PERMIT SET
05/08/2024 CONSTRUCTION SET

Revisions:
2 4/25/24 PLAN REVIEW COMMENTS

Drawn: CJK
Checked: JEJ

Project No:
2301004

Contents:

HVAC PLAN

M100

SANITIZING EQUIPMENT SCHEDULE

TAG	COUNT	DESCRIPTION	FURNISHED BY	INSTALLED BY	BASIS FOR DESIGN		REMARKS
					MANUFACTURER	MODEL	
SB-1	2	BATHROOM AIR PURIFICATION UNIT	TUV	GC	RGF ENVIRONMENTAL GROUP	BRU ASSEMBLY	SEE ELECTRICAL SHEETS FOR CONNECTION INFORMATION
SH-1	2	HVAC AIR PURIFICATION UNIT	TUV	GC	RGF ENVIRONMENTAL GROUP	REME-HALO	SEE DETAIL 6/M700 FOR INSTALLATION INFORMATION.
SI-1	3	ICE MACHINE TREATMENT SYSTEM	TUV	GC	RGF ENVIRONMENTAL GROUP	IMS-B-GA	SEE PLUMBING DRAWINGS FOR INSTALLATION INFORMATION.

VIROGUARD SCHEDULE

TAG	QUANTITY	DESCRIPTION	DUCT CONNECTION SIZE	FAN	FURNISHED BY	INSTALLED BY	BASIS FOR DESIGN MANUFACTURER
VG-1	1	VIROGUARD HOOD EXHAUST FAN ROOFTOP CONTAINMENT SYSTEM	16" X 16"	CAPTIVE-AIRE DU180HFA	TDC	GC	ENVIROMATIC

GRILLS, REGISTERS, AND DIFFUSERS SCHEDULE

TAG	DESCRIPTION	FACE SIZE	MATERIAL	FINISH	MOUNTING	FURNISHED BY	INSTALLED BY	BASIS FOR DESIGN		NOTES
								MANUFACTURER	MODEL	
CD1	PERFORATED CEILING DIFFUSER	24" X 24"	ALUMINUM	WHITE	LAY-IN CEILING	GC	GC	NAILOR	4320A TYPE L	PROVIDE INTEGRAL OBD
CD4	PERFORATED CEILING DIFFUSER	12" X 12"	ALUMINUM	WHITE	GYP CEILING	GC	GC	NAILOR	4320A TYPE S	PROVIDE INTEGRAL OBD
ER1	PERFORATED CEILING EXHAUST	12" X 12"	ALUMINUM	WHITE	GYP CEILING	GC	GC	NAILOR	4330R TYPE S	PROVIDE INTEGRAL OBD
RG1	PERFORATED CEILING RETURN	48" X 24"	ALUMINUM	WHITE	LAY-IN CEILING	GC	GC	NAILOR	4330R TYPE L	
RG2	PERFORATED CEILING RETURN	48" X 24"	ALUMINUM	WHITE	GYP CEILING	GC	GC	NAILOR	4330R TYPE S	
SR1	ADJUSTABLE TURBO NOZZLE	SEE NECK SIZE	ALUMINUM	WHITE	WALL	GC	GC	AIR CONCEPTS	ANR-10	PROVIDE FACE-ACCESSIBLE OBD
SR2	DOUBLE DEFLECTION SUPPLY REGISTER	SEE NECK SIZE	ALUMINUM	WHITE	WALL	GC	GC	NAILOR	51DH	PROVIDE INTEGRAL OBD

FAN SCHEDULE

TAG	DRIVE TYPE	EXHAUST FLOW [CFM]	E.S.P. [in W.C.]	WEIGHT [lbs]	ELECTRICAL		FURNISHED BY	INSTALLED BY	BASIS FOR DESIGN		REMARKS
					MOTOR POWER	V/P/H			MANUFACTURER	MODEL	
EF-1	DIRECT	2550 CFM	1.20 in-wg	400	2	208/3/60	HS	GC	CAPTIVE-AIRE	DU180HFA	FURNISHED WITH DISCONNECT AND VENTED ROOF CURB
EF-2	DIRECT	150 CFM	0.60 in-wg	100	0.18 HP	120/1/60	HS	GC	CAPTIVE-AIRE	DR12HFA	FURNISHED WITH DISCONNECT, VARIABLE SPEED CONTROLLER, BACKDRAFT DAMPER AND ROOF CURB

MAKEUP AIR UNIT SCHEDULE

TAG	DESCRIPTION	AIRFLOW		HEATING CAPACITY				APPROXIMATE WEIGHT [lbs]	ELECTRICAL		FURNISHED BY	INSTALLED BY	BASIS FOR DESIGN		REMARKS
		SUPPLY FLOW [CFM]	E.S.P. [in. W.C.]	INPUT [MBH]	OUTPUT [MBH]	MAXIMUM TURNDOWN	EAT		MOTOR POWER	V/P/H			MANUFACTURER	MODEL	
MAU-1	MAKEUP AIR UNIT	1300	0.80	225	220	12.5:1	12 °F	650	1 HP	208/3/60	HS	GC	CAPTIVE-AIRE	A1-D-250-15D	FURNISHED WITH DISCONNECT, ROOF CURB, SCREEN INTAKE, AND WASHABLE ALUMINUM FILTERS

CONDENSING UNIT SCHEDULE

TAG	DESCRIPTION	NOMINAL CAPACITY [TONS]	NUMBER OF COMPRESSORS	NUMBER OF CIRCUITS	REFRIGERANT TYPE	REFRIGERANT CHARGE	WEIGHT	ELECTRICAL			FURNISHED BY	INSTALLED BY	BASIS FOR DESIGN		REMARKS
								MOCP	FLA	V/P/H			MANUFACTURER	MODEL	
CU-1	WALK-IN COOLER REMOTE CONDENSING UNIT	--	1	1	R-404A		200	15 A	6.5 A	208/3/60	WCS	GC	HARFORD	PCL99MOP-3	FURNISHED WITH WALK-IN COOLER
CU-2	ICE MAKER - REMOTE CONDENSER	--	0	1	R-404A	11 lbs 7.4 oz	100			120/1/60	KES	GC	-	-	FURNISHED WITH ICE MAKER
CU-3	ICE MAKER - REMOTE CONDENSER	--	0	1	R-404A	11 lbs 7.4 oz	100			120/1/60	KES	GC	-	-	FURNISHED WITH ICE MAKER

KITCHEN HOOD SCHEDULE

TAG	DESCRIPTION	MAX COOKING TEMP.	EXHAUST PLENUM							PERFORATED SUPPLY PLENUMS										NUMBER OF LIGHT FIXTURES	APPROXIMATE WEIGHT [lbs]	FURNISHED BY	INSTALLED BY	BASIS FOR DESIGN		REMARKS
			AIRFLOW [CFM]	SP [in. W.C.]	DUCT COLLARS			LENGTH	WIDTH	SP [in. W.C.]	SUPPLY PLENUM LENGTH	SUPPLY PLENUM WIDTH	MAU PLENUM			AC PLENUM		MANUFACTURER	MODEL							
					NO.	WIDTH	LENGTH						AIRFLOW [CFM]	DUCT COLLARS		AIRFLOW [CFM]	DUCT COLLARS									
														NO.	WIDTH		LENGTH							NO.	DIAMETER	
HD-1	TYPE I CANOPY HOOD WITH PERFORATED MAU AND AC SUPPLY PLENUMS	600°F	2550	0.97	1	10"	24"	12' - 9"	4' - 3"	0.1	13' - 9"	19"	1300	3	6"	28"	1700	6	8"	8	1100	HS	GC	CAPTIVE-AIRE	5424 ND-2-ACPS-P	MAT'L: 18 GA. TYPE 430 SS. PROVIDE WITH VERTICAL END PANELS, 16" TALL HE SS FILTERS, INTEGRAL UTILITY CABINET, ANSUL SYSTEM, DUCT COLLAR TEMPERATURE SENSOR, PREWIRE PACKAGE, SPARE FIRE SYSTEM DRY CONTACT, AND 4-POLE 20A CONTACTOR

ROOFTOP UNIT SCHEDULE

TAG	DESCRIPTION	NOMINAL CAPACITY [TONS]	EER	AIRFLOW			NET COOLING CAPACITY				HEATING CAPACITY			# OF COMPRESSORS	# OF CIRCUITS	REFRIG. TYPE	REFRIG. CHARGE	APPROX. WEIGHT [lbs]	ELECTRICAL			FURNISHED BY	INSTALLED BY	BASIS FOR DESIGN		REMARKS	
				TOTAL [CFM]	OA [CFM]	ESP [IN. W.C.]	TOTAL [MBH]	SENSIBLE [MBH]	EAT [DEG. F]	COND. EAT [DEG. F]	INPUT [MBH]	OUTPUT [MBH]	EAT [DEG. F]						MOCP	FLA	V/P/H			MANUFACTURER	MODEL		
RTU-1	KITCHEN ROOFTOP UNIT	10	12	3500	500	0.8	118	76	76	66	92	250	205	59	2	2	R-410A	25.6	1500	60 A	49.0 A	208/3/60	HES	GC	CARRIER	48FC_M12	FURNISHED WITH HINGED ACCESS PANELS, STANDARD ECONOMIZER W/ DUAL ENTHALPY CONTROLS, BAROMETRIC RELIEF, W/ REMOTE KEYED ANNUNCIATOR/RESET, MERV-8 FILTERS, CURB, HAIL GUARD, DISCONNECT, & UNIT-MOUNTED NON-POWERED CONVENIENCE RECEPTACLE
RTU-2	DINING ROOM ROOFTOP UNIT	10	12	4000	1000	0.8	127	74	78	69	92	250	205	52	2	2	R-410A	25.6	1500	60 A	49.0 A	208/3/60	HES	GC	CARRIER	48FC_M12	FURNISHED WITH HINGED ACCESS PANELS, STANDARD ECONOMIZER W/ DUAL ENTHALPY CONTROLS, BAROMETRIC RELIEF, W/ REMOTE KEYED ANNUNCIATOR/RESET, MERV-8 FILTERS, CURB, HAIL GUARD, DISCONNECT, & UNIT-MOUNTED NON-POWERED CONVENIENCE RECEPTACLE
GC TO COORDINATE CONTROL WITH GRIDPOINT SO ONLY FIRST STAGE HEATING IS ACTIVE ON RTU-1																											

GC TO COORDINATE CONTROL WITH GRIDPOINT SO ONLY FIRST STAGE HEATING IS ACTIVE ON RTU-1

Consultant:



4635 Trueman Blvd, Suite 250
Hilliard, Ohio 43026
Phone: (614) 751-9610
Fax: (614) 552-5240
Contact: Cliff Kigar
(614) 328-2033
ckigar@nationalengineering.com

FOR CONSTRUCTION

COPYRIGHT 2024
THIS DRAWING IS AN INSTRUMENT OF SERVICE
AND AS SUCH REMAINS THE PROPERTY OF
CHIPOTLE MEXICAN GRILL, INC.. PERMISSION FOR
USE OF THIS DOCUMENT IS LIMITED AND CAN BE
EXTENDED ONLY BY WRITTEN AGREEMENT WITH
CHIPOTLE MEXICAN GRILL, INC..



CHIPOTLE MEXICAN GRILL, INC.
PO BOX 182566
COLUMBUS, OH 43218-2566
TELEPHONE: (614) 318-2400
INTERNET: WWW.CHIPOTLE.COM

STORE NO.: 4870
WALNUT HILLS, OH
1202 E. MCMILLAN
CINCINNATI, OH 45206

Issue Record:
11/03/2023 PERMIT SET
05/08/2024 CONSTRUCTION SET

Revisions:
2 4/25/24 PLAN REVIEW COMMENTS


Drawn: CJK
Checked: JEJ

Project No:
2301004


Contents:

HVAC SCHEDULES


M600

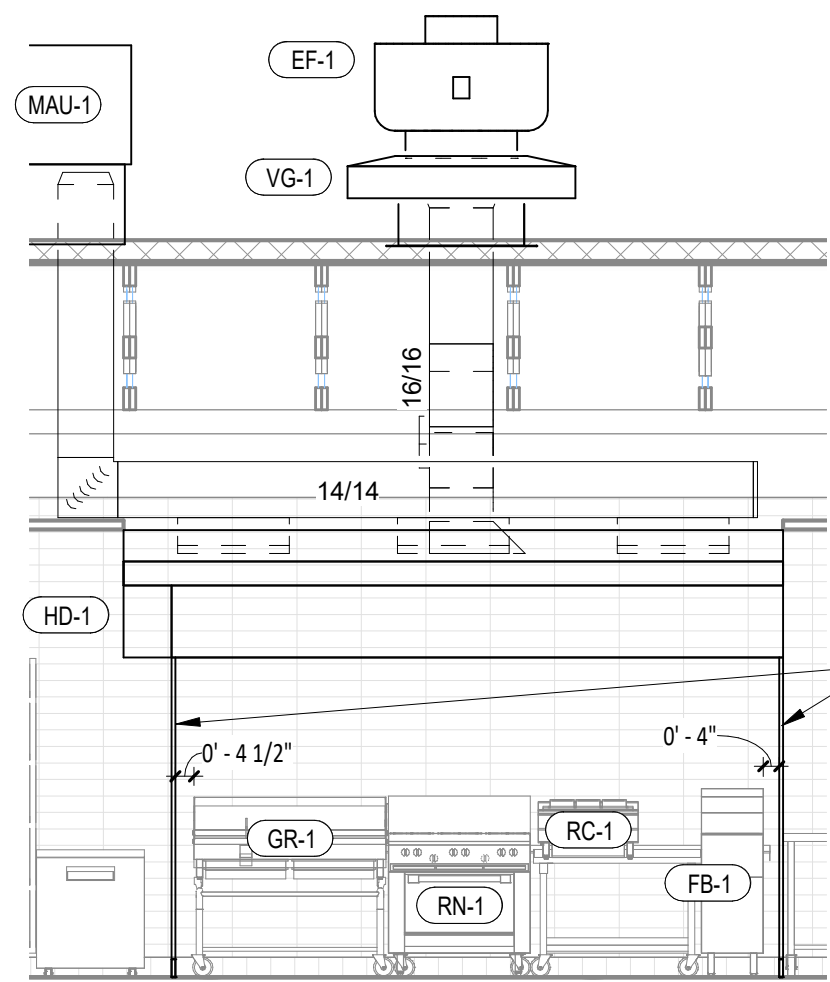


10
M700
HOOD ELEVATION
1/4" = 1'-0"

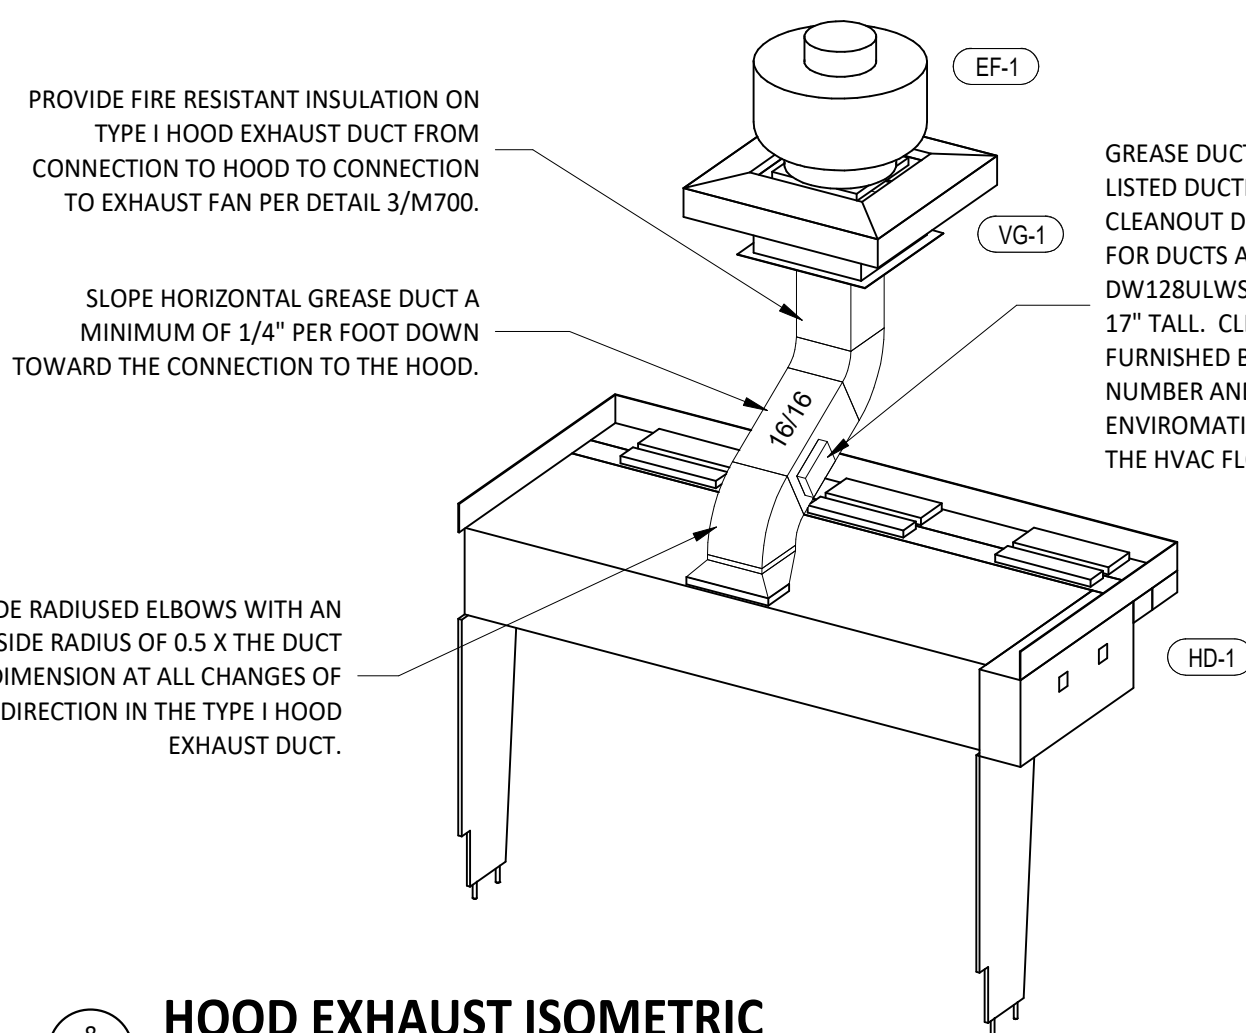


8
M700
HOOD EXHAUST ISOMETRIC
N.T.S.

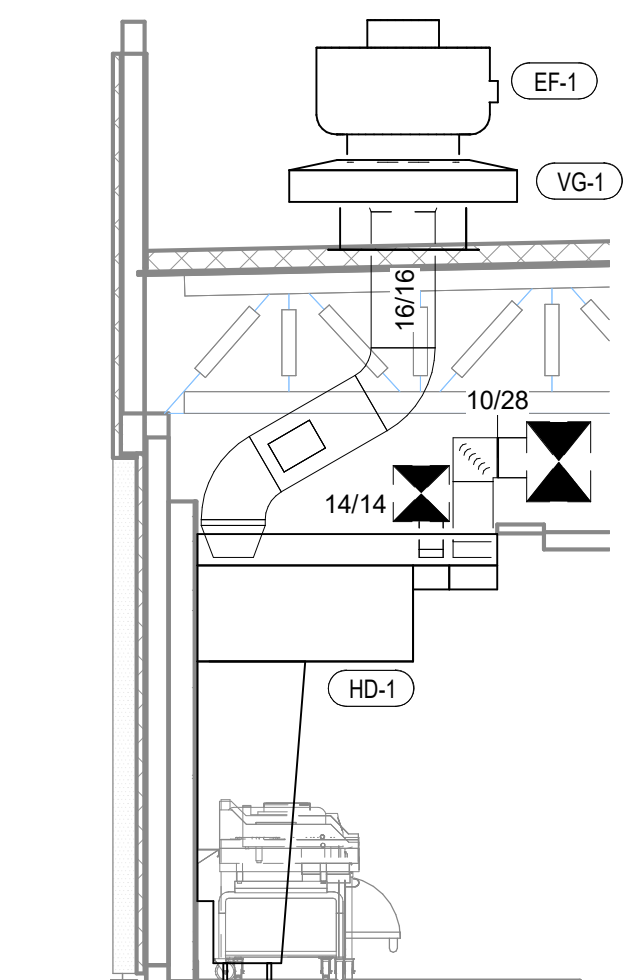


7
M700
DUCT SECTION AT HOOD
1/4" = 1'-0"

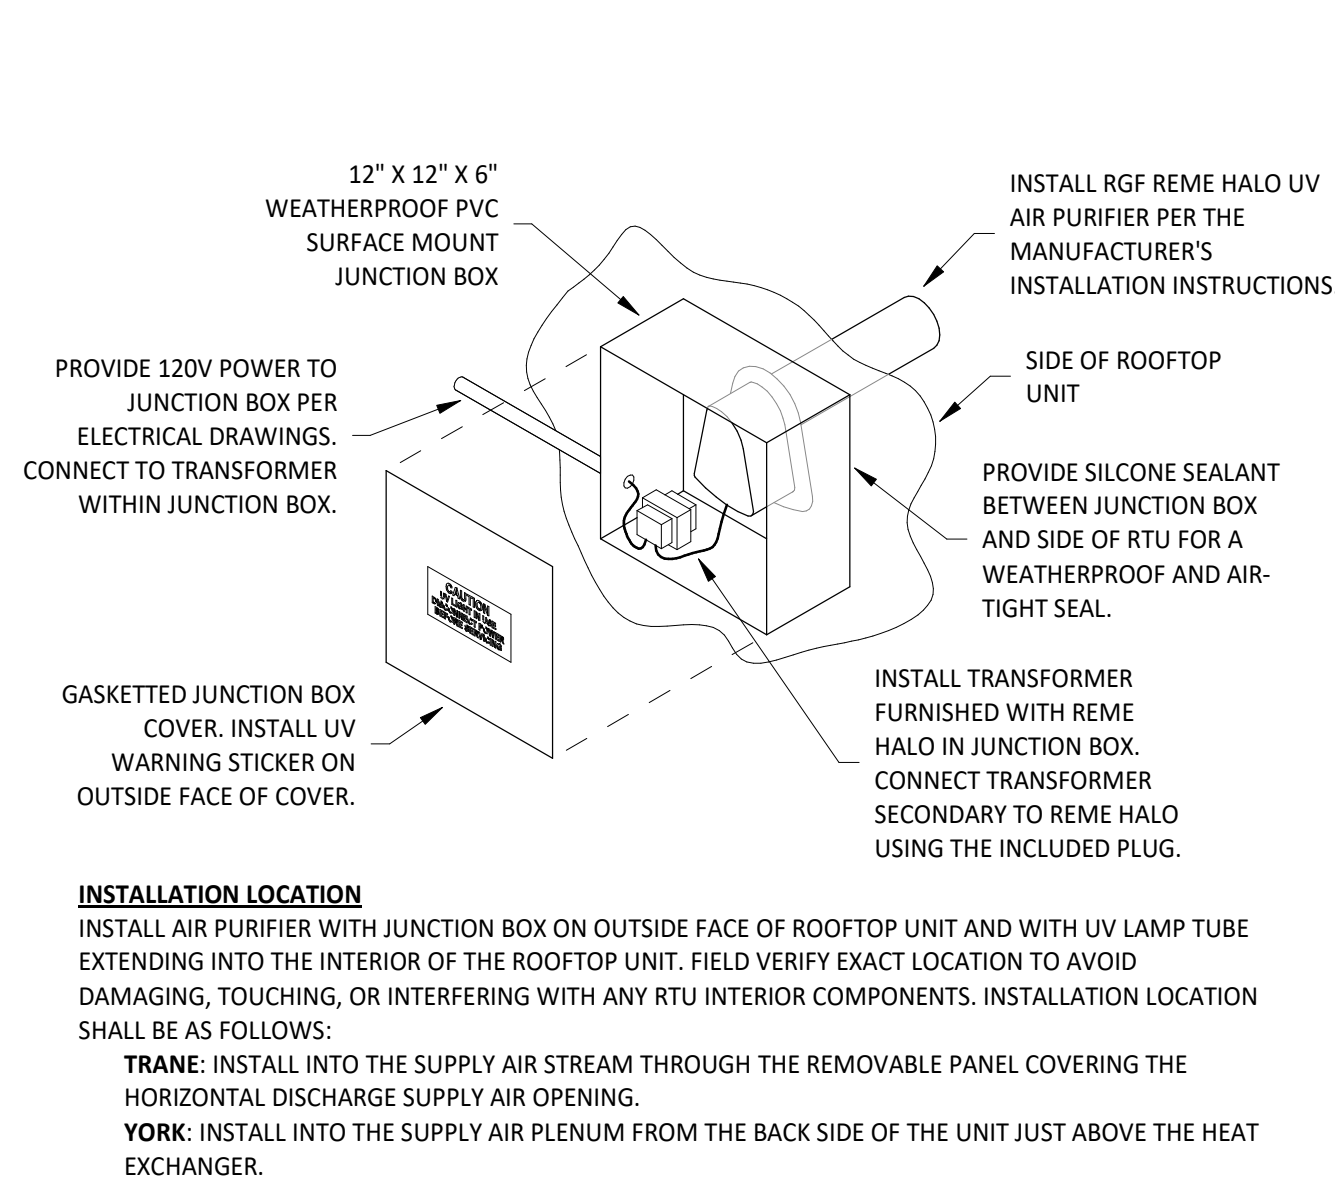


6
M700
UV AIR PURIFIER INSTALLATION
N.T.S.

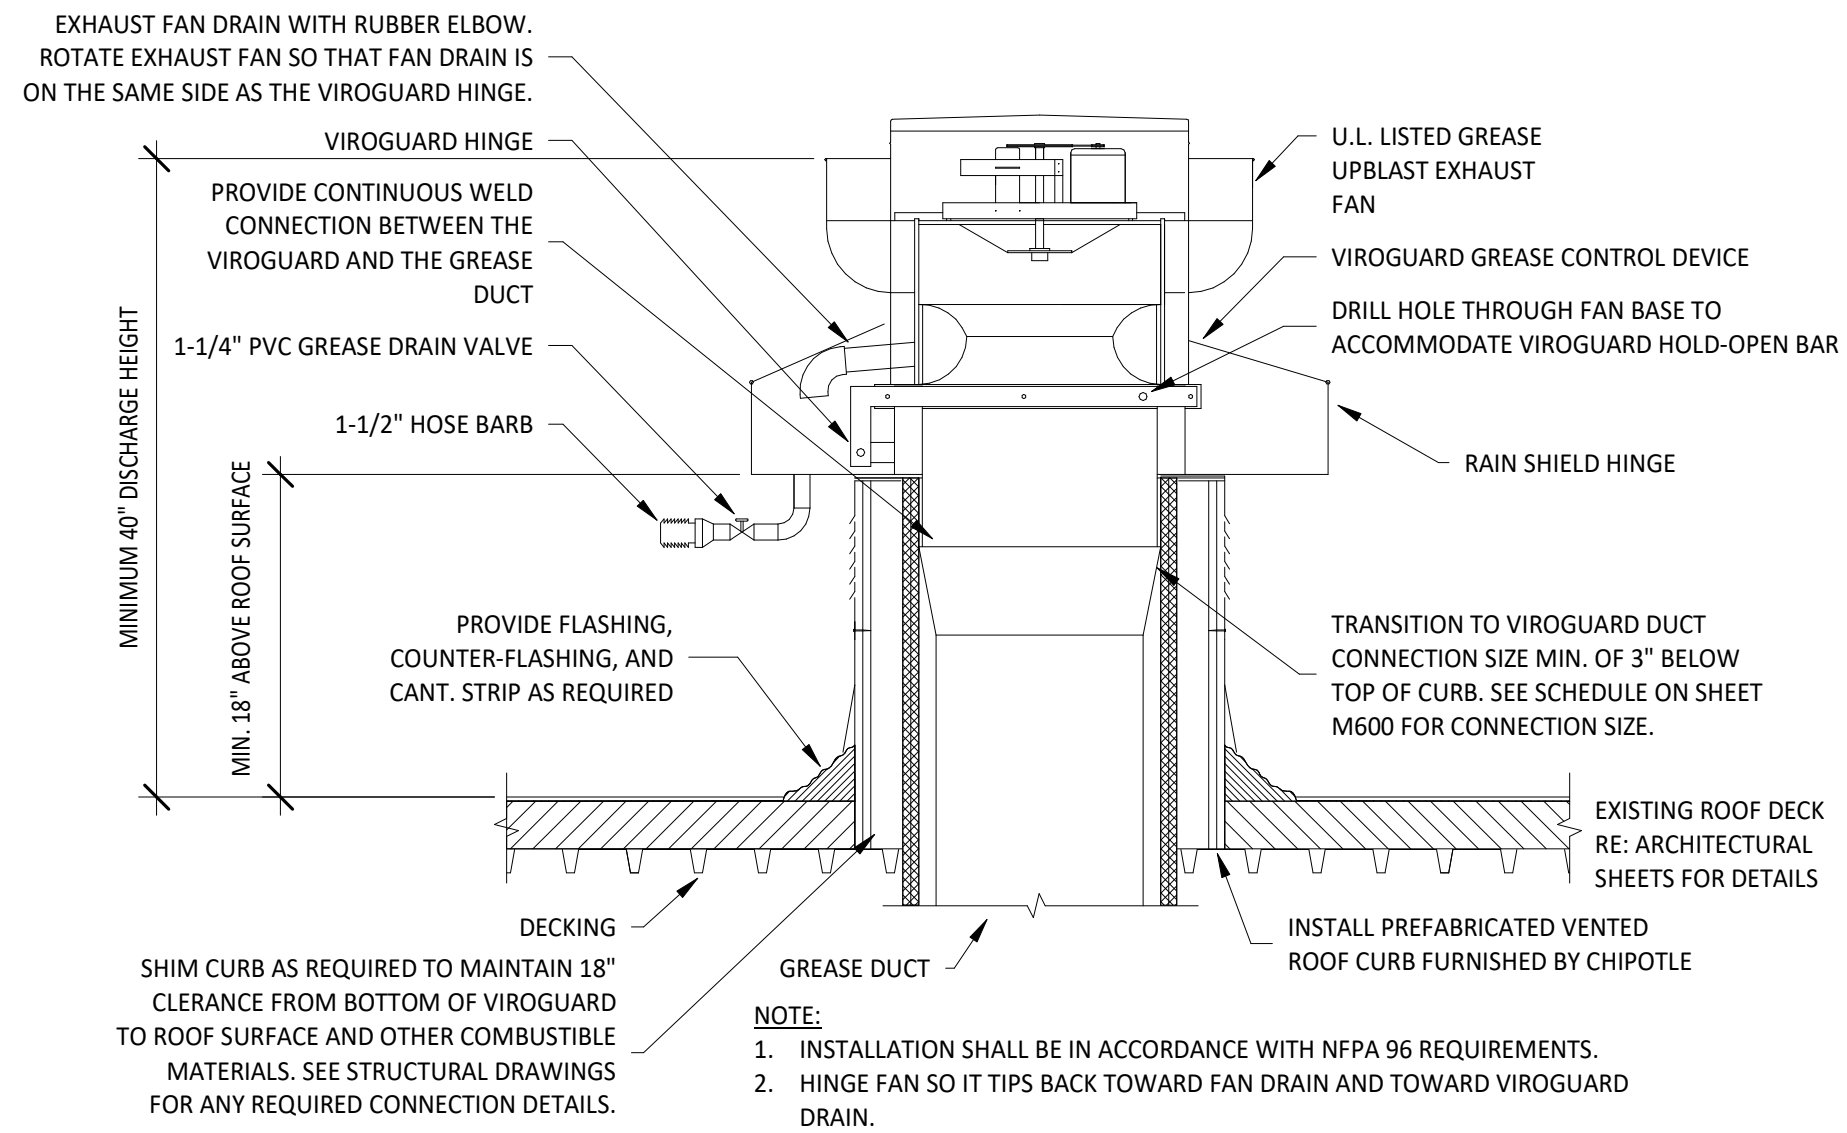


5
M700
GREASE EXHAUST FAN
N.T.S.

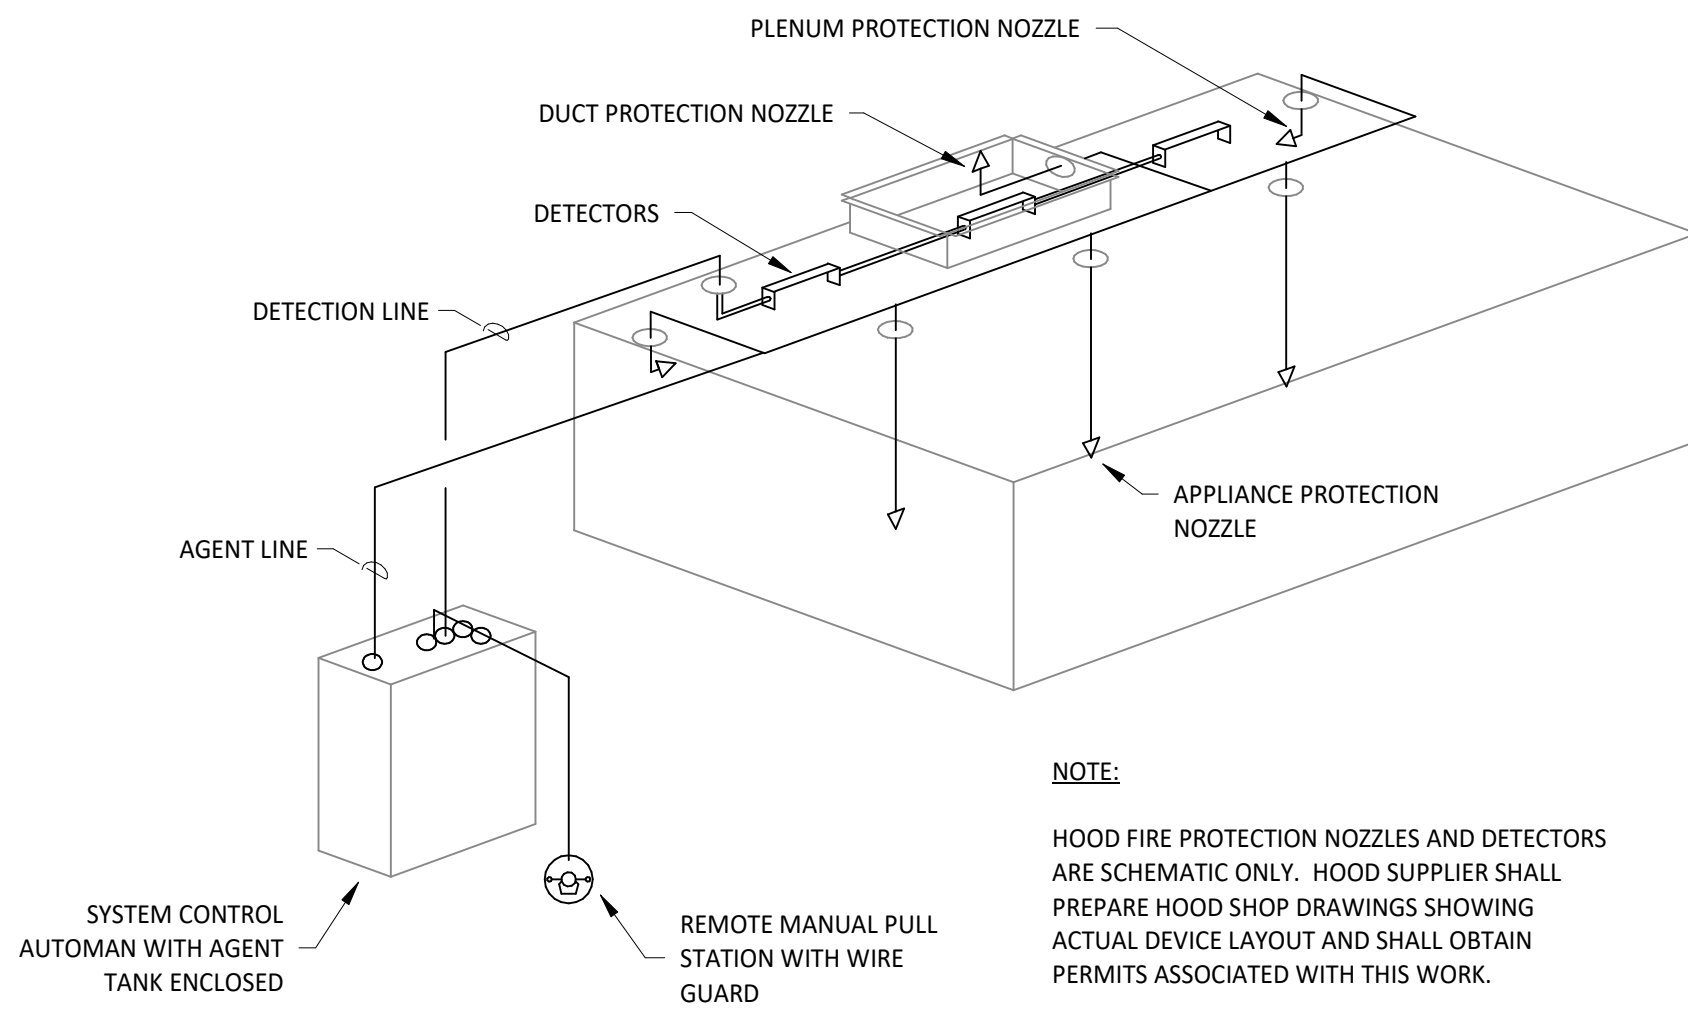


4
M700
FIRE SUPPRESSION SYSTEM SCHEMATIC
N.T.S.

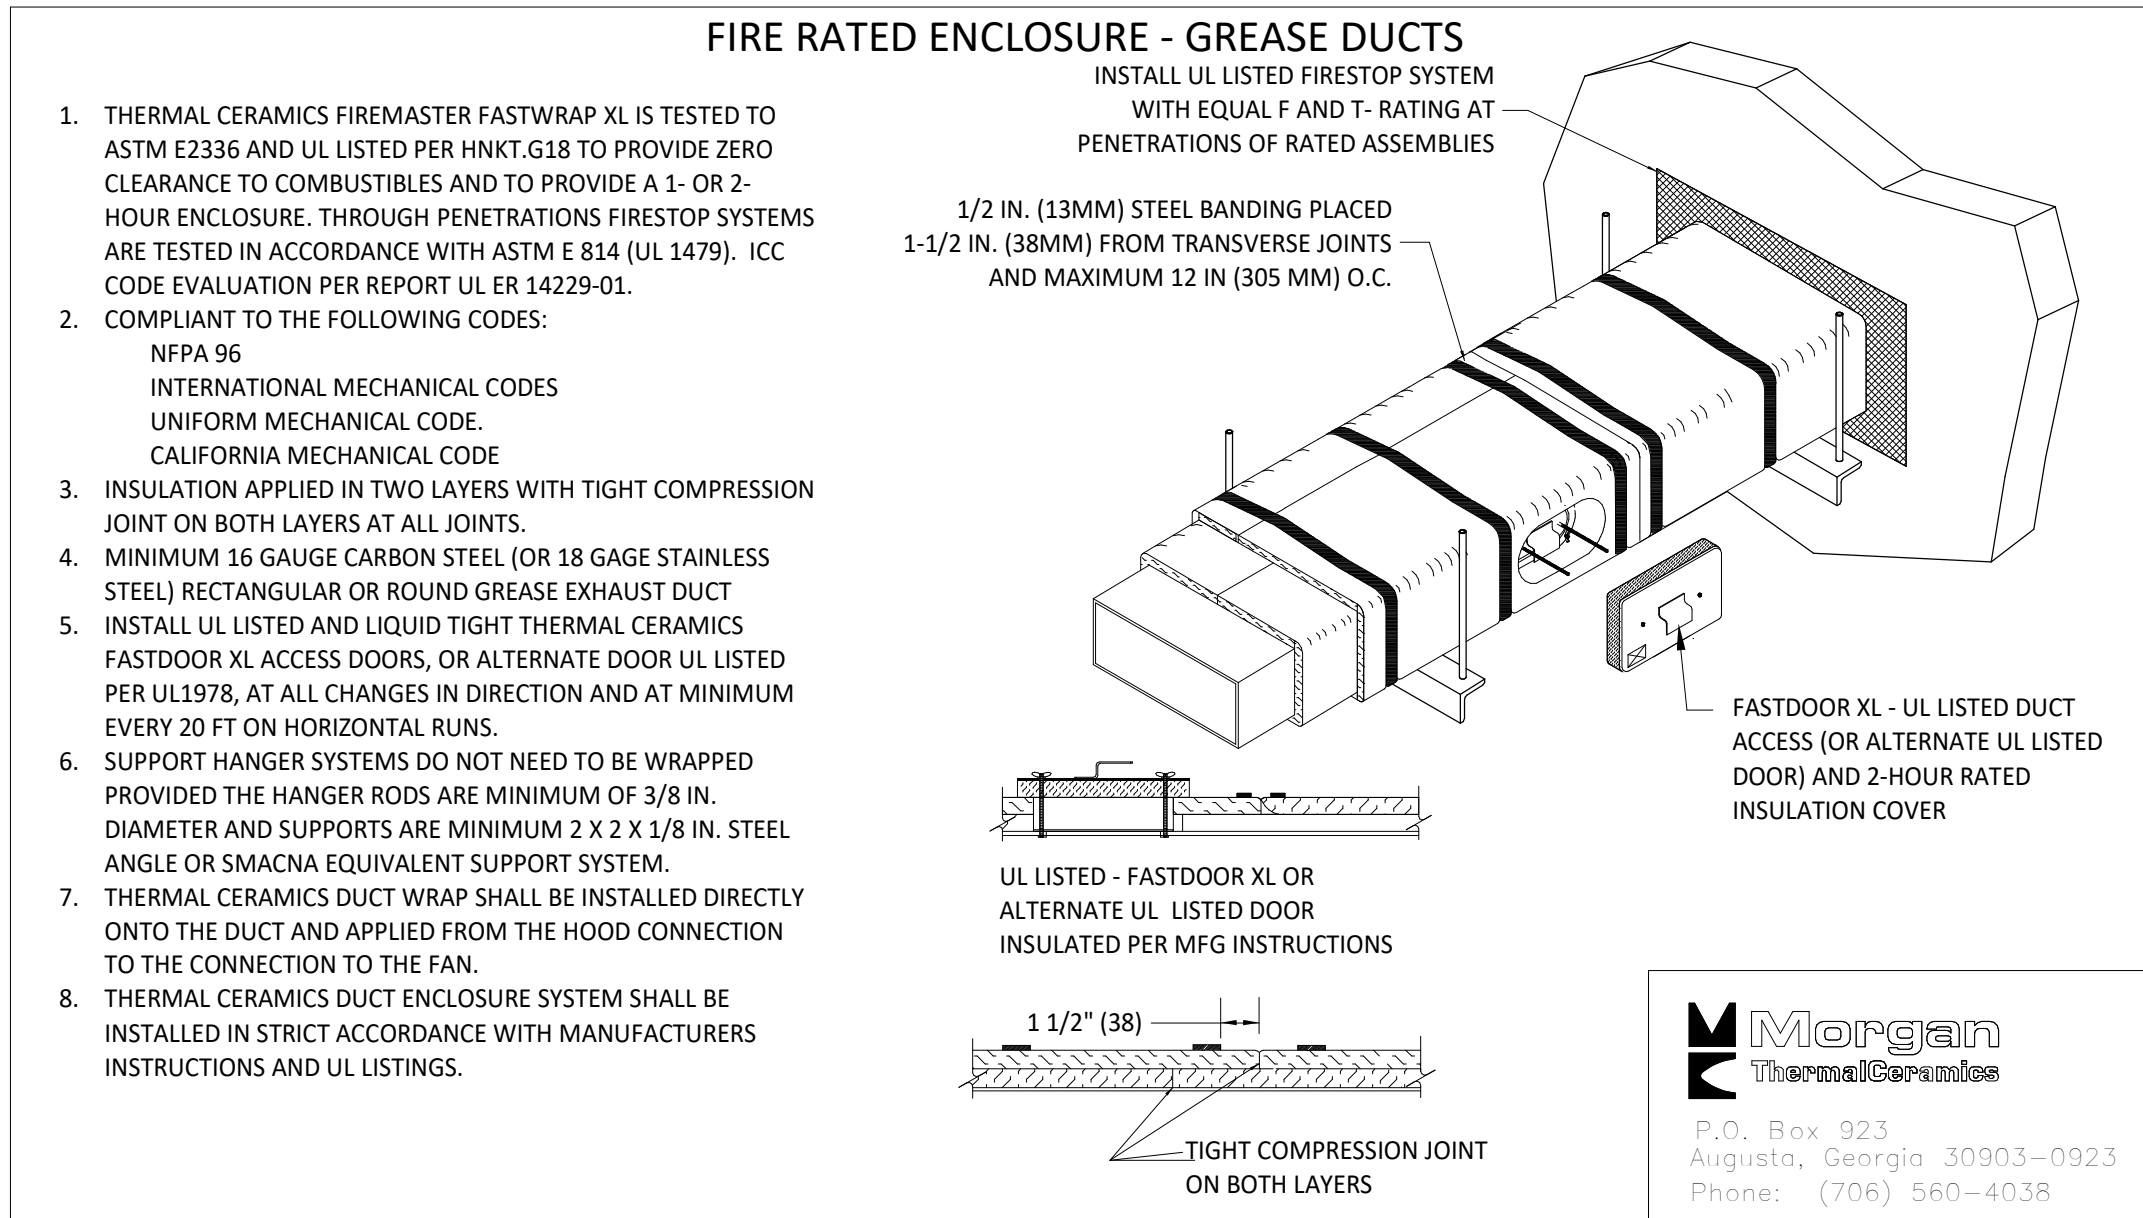

3
M700
FIREMASTER DUCT WRAP - UL HNKT-G18
N.T.S.

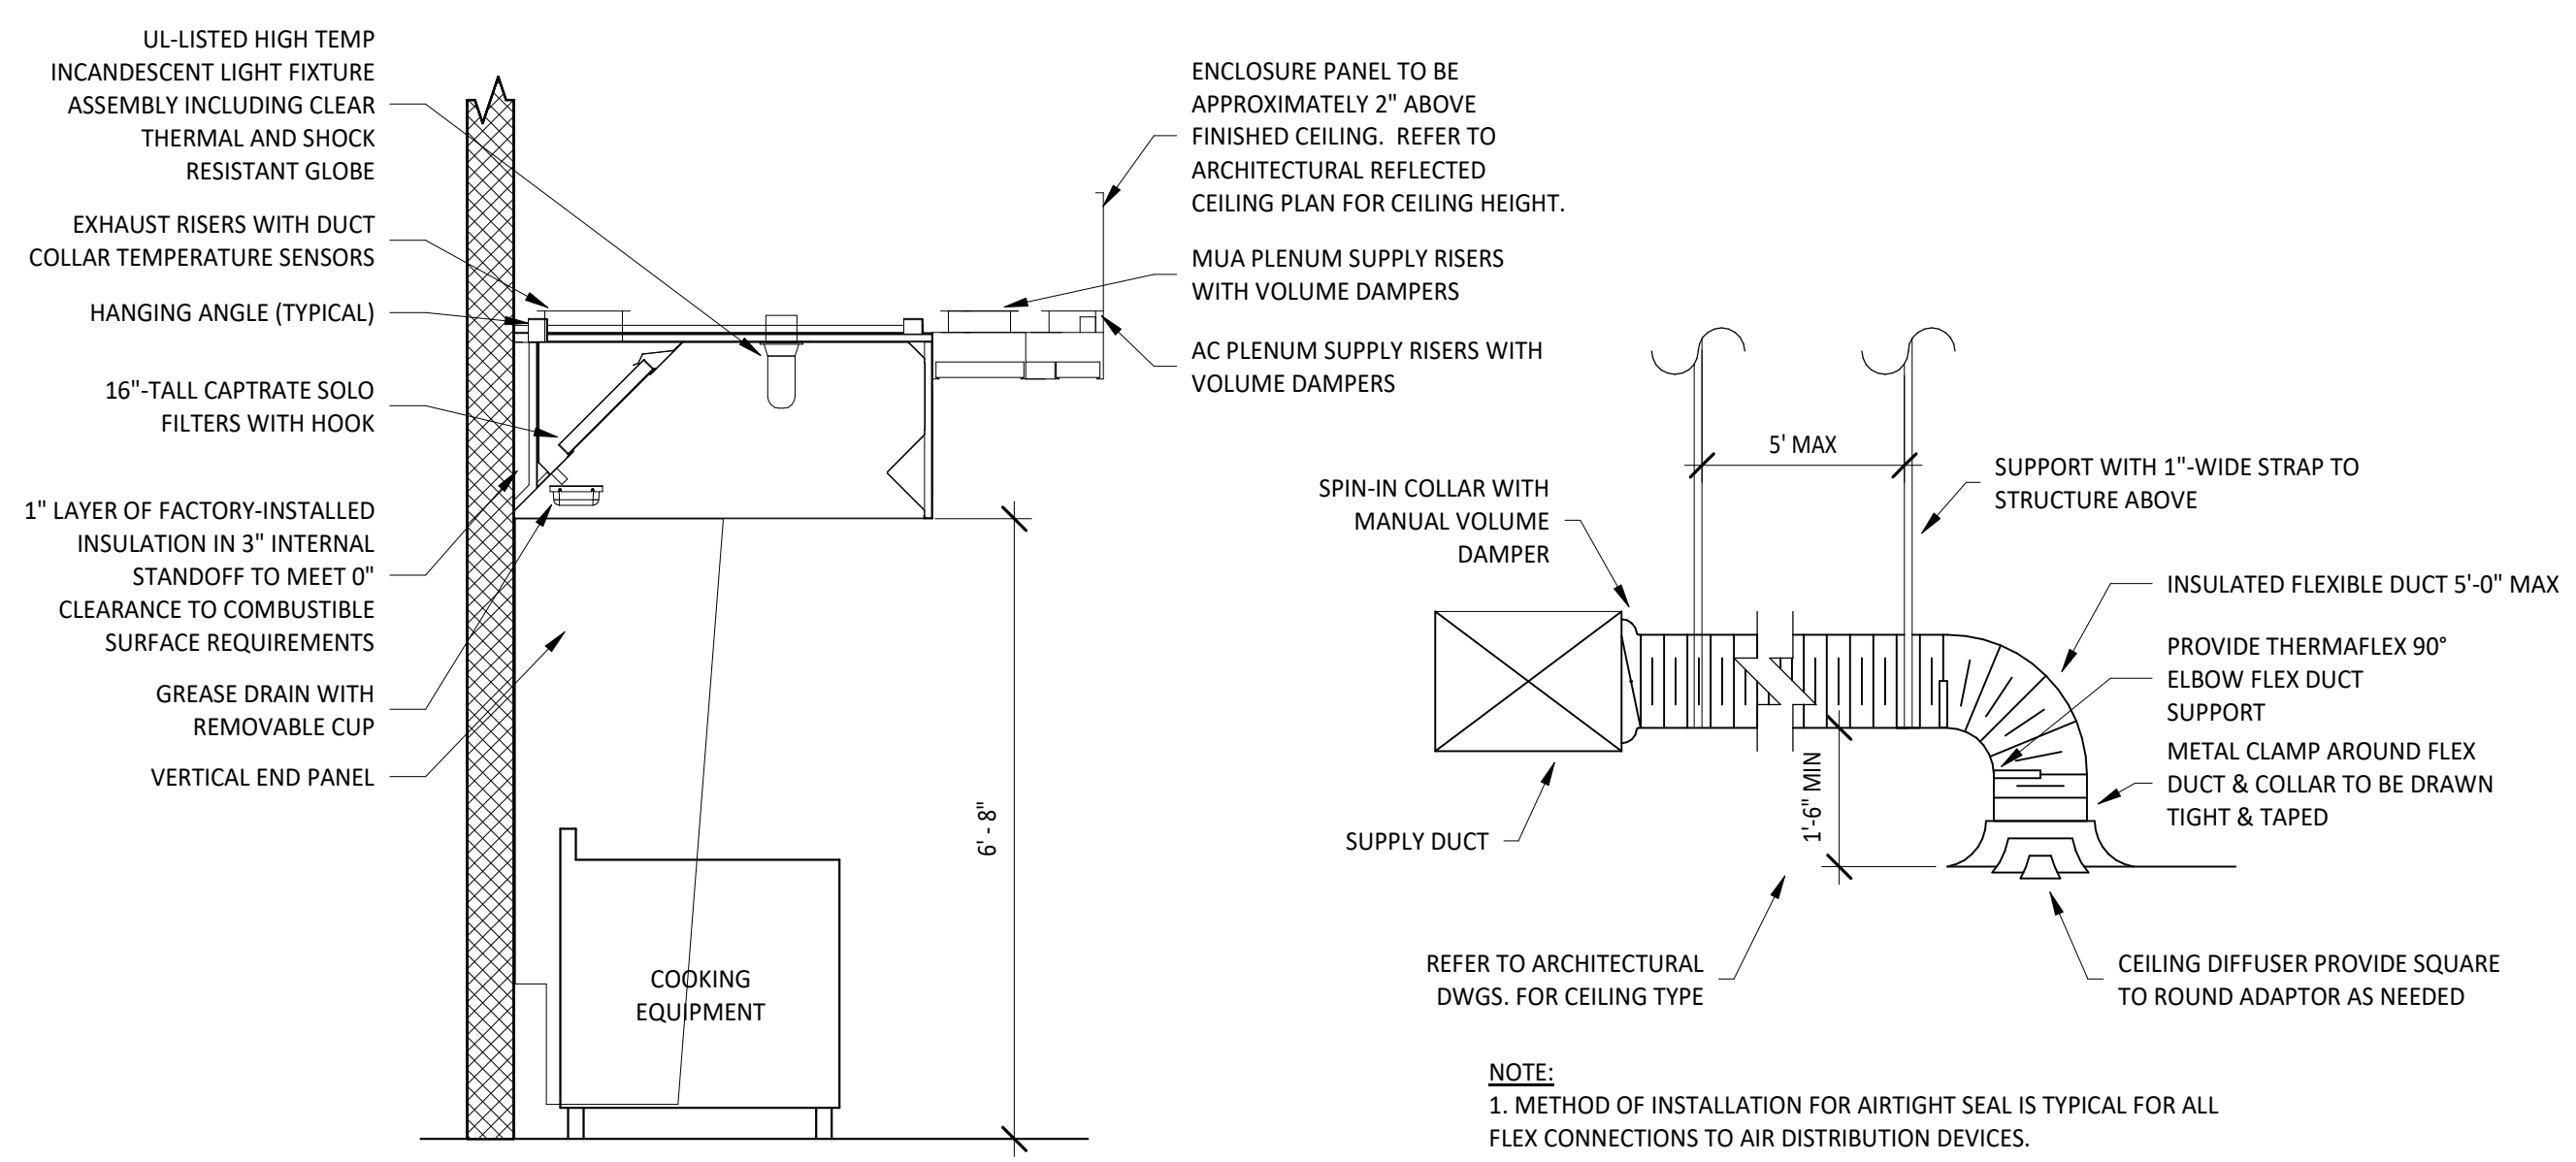

2
M700
HOOD SECTION VIEW
N.T.S.

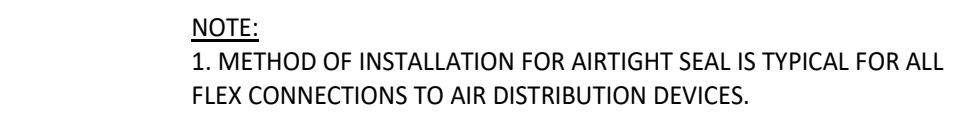

1
M700
DIFFUSER CONNECTION
N.T.S.

Consultant:
NATIONAL ENGINEERING
4635 Trueman Blvd, Suite 250
Hilliard, Ohio 43026
Phone: (614) 751-9610
Fax: (614) 552-5240
Contact: Cliff Kigar
(614) 328-2033
ckigar@nationalengineering.com

FOR CONSTRUCTION

COPYRIGHT 2024
THIS DRAWING IS AN INSTRUMENT OF SERVICE AND AS SUCH REMAINS THE PROPERTY OF CHIPOTLE MEXICAN GRILL, INC.. PERMISSION FOR USE OF THIS DOCUMENT IS LIMITED AND CAN BE EXTENDED ONLY BY WRITTEN AGREEMENT WITH CHIPOTLE MEXICAN GRILL, INC..



CHIPOTLE MEXICAN GRILL, INC.
PO BOX 182566
COLUMBUS, OH 43218-2566
TELEPHONE: (614) 318-2400
INTERNET: WWW.CHIPOTLE.COM

STORE NO.: 4870
WALNUT HILLS, OH
1202 E. MC MILLAN
CINCINNATI, OH 45206

Issue Record:	
11/03/2023	PERMIT SET
05/08/2024	CONSTRUCTION SET

Revisions:	
2 4/25/24	PLAN REVIEW COMMENTS

Drawn: CJK
Checked: JEJ

Project No:
2301004

Contents:

HVAC DETAILS

M700

SECTION 15055 - COMMON PIPING REQUIREMENTS

- PART 1 - GENERAL
- A. SECTION REQUIREMENTS
1. Comply with the requirements of the Building Code and the local authority having jurisdiction.
- PART 2 - PRODUCTS
- 2.1 SUPPORTING DEVICES
- A. Hanger and Pipe Attachments: Factory fabricated with galvanized coatings; nonmetallic coated for hangers in direct contact with copper tubing.
- B. Building Attachments: Powder actuated type, drive pin attachments with pullout and shear capacities appropriate for supported loads and building materials; UL listing and FM approval for fire protection systems.
- C. Mechanical Anchor Fasteners: Insert-type attachments with pullout and shear capacities appropriate for supported loads and building materials; UL listing and FM approval for fire protection systems.
- PART 3 - EXECUTION
- 3.1 INSTALLATION
- A. Install piping free of sags and bends.
- B. Install fittings for changes in direction and branch connections.
- C. Install sleeves for pipes passing through concrete and masonry walls, gypsum board partitions, and concrete floor and roof slabs.
- D. Exterior Wall, Pipe Penetrations: Mechanical sleeve seals installed in steel or cast iron pipes for wall sleeves.
- E. Fire Barrier Penetrations: Seal pipe penetrations with through-penetration firestop systems.
- F. Install unions adjacent to each valve and at final connection to each piece of equipment.
- G. Install dielectric unions and flanges to connect piping materials of dissimilar metals in gas piping.
- H. Install dielectric coupling and nipple fittings to connect piping materials of dissimilar metals in water piping.
- I. Provide full ring escutcheons at plumbing penetrations through walls or ceilings. Tightly seal escutcheons to the adjacent surface.
- 3.2 HANGERS AND SUPPORTS
- A. Install building attachments within concrete or to structural steel. Install additional attachments at concentrated loads, including valves, flanges, guides, strainers, expansion joints, and at changes in direction of piping.
- B. Install powder actuated drive pin fasteners in concrete after concrete is cured. Do not use in lightweight concrete or in slabs less than 4 inches thick.
- C. Install mechanical anchor fasteners in concrete after concrete is cured. Do not use in lightweight concrete or in slabs less than 4 inches thick.
- D. Support fire protection system piping independent of other piping.
- E. Load Distribution: Install hangers and supports so piping live and dead loading and stresses from movement will not be transmitted to connected equipment.
- END OF SECTION 15055

SECTION 15080 - MECHANICAL INSULATION

- PART 1 - GENERAL
- 1.1 SECTION REQUIREMENTS
- A. Submittals: None.
- B. Quality Assurance: Label with maximum flame-spread rating of 25 and maximum smoke developed rating of 50 according to ASTM E 84.
- PART 2 - PRODUCTS
- 2.1 PIPE INSULATION
- A. Preformed Glass Fiber Pipe Insulation: ASTM C 547, Class 1, with factory applied, all purpose, vapor retarder jacket.
- B. Polyolefin Pipe Insulation: Unicellular polyethylene, preformed pipe insulation. Comply with ASTM C 534, Type I, except for density.
- PART 3 - EXECUTION
- 3.1 INSTALLATION
- A. Install vapor barriers on insulated pipes with surface operating temperatures below 60 deg F.
- B. Insulate fittings, valves, and specialties.
- C. Seal vapor barrier penetrations for hangers, supports, anchors, and other projections.
- D. Coat glass fiber pipe insulation ends with vapor barrier coating.
- E. Roof Penetrations: Apply insulation for interior applications to a point even with the top of the roof flashing.
- F. Exterior Wall Penetrations: For penetrations of below grade exterior walls, terminate insulation flush with mechanical sleeve seal.
- G. Interior Walls and Partitions Penetrations: Apply insulation continuously through walls and partitions, except fire rated walls and partitions.
- H. Fire Rated Walls and Partitions Penetrations: Terminate insulation at penetrations through fire rated walls and partitions. Seal around penetration with through penetration firestop systems.
- I. Floor Penetrations: Terminate insulation at the underside of the floor assembly and at the floor support at top of floor. Seal around penetration with through penetration firestop systems.
- J. Glass Fiber Insulation Installation: Bond insulation to pipe with adhesive. Seal seams and joints with vapor barrier compound.
- K. Interior Piping System Applications: Insulate the following piping systems:
1. Domestic cold, hot, and recirculation water pipes.
 2. Exposed sanitary drains and water supply pipes for public hand sinks.
 3. Refrigerant piping.
- L. Do not apply insulation to the following systems, materials, and equipment:
1. Flexible connectors.
 2. Fire protection piping systems.
 3. Sanitary drainage and vent piping.
 4. Chrome plated pipes and fittings, except for plumbing fixtures for the disabled.
 5. Piping specialties, including air chambers, unions, strainers, check valves, plug valves, and flow regulators.
- M. Pipe Insulation Thickness Application Schedule: Insulate piping with the following materials and thicknesses:
1. Domestic Hot and Recirculation water pipes: 1-inch preformed glass fiber pipe insulation.
 2. Domestic Cold Water: 1/2-inch preformed glass fiber pipe insulation.
 3. P-Trap and Fixture Supplies for public hand sinks: ADA-compliant pre-formed insulation.
- END OF SECTION 15080

SECTION 15110 - VALVES

- PART 1 - GENERAL (Not Applicable)
- PART 2 - PRODUCTS
- 2.1 GENERAL DUTY VALVES
- A. End Connections: Threads shall comply with ANSI B1.20.1. Flanges shall comply with ANSI B16.1 for cast iron valves and ANSI B16.24 for bronze valves. Solder-joint connections shall comply with ANSI B16.18.
- B. Ball Valves: Rated for 150 psig saturated steam pressure, 400 psig WOG pressure; 2 piece construction; with bronze body, standard (or regular) port, chrome plated brass ball, replaceable "Teflon" or "TFE" seats and seals, blowout proof stem, and vinyl covered steel handle.
- C. Plug Valves: Rated at 150 psig WOG; bronze body, with straightaway pattern, square head, and threaded ends.
- D. Swing Check Valves: Class 125, cast bronze body and cap; with horizontal swing, Y-pattern, and bronze disc.
- E. Valves for Copper Tube: Solder ends, except provide threaded ends for heating hot water and low pressure steam service.
- F. Valves for Steel Pipe: Threaded ends.
- PART 3 - EXECUTION
- 3.1 INSTALLATION
- A. Use gate and ball valves for shutoff duty and ball for throttling duty.
- B. Locate valves for easy access and provide separate support where necessary.
- C. Install accessible valves for each fixture and item of equipment.
- D. Install valves in horizontal piping with stem at or above center of pipe.
- E. Install valves in a position to allow full stem movement.
- F. Install check valves for proper direction of flow in horizontal position with hinge pin level.
- END OF SECTION 15110

SECTION 15140 - DOMESTIC WATER PIPING

- PART 1 - GENERAL
- 1.1 SECTION REQUIREMENTS
- A. Performance Requirements: Unless otherwise indicated minimum pressure requirements for water piping are as follows:
1. Service Entrance Piping: 100 psig.
 2. Domestic Water Piping: 80 psig.
- B. Comply with NSF 14 "Plastic Piping Components and Materials."
- C. Comply with NSF 61 "Drinking Water System Components -- Health Effects."
- PART 2 - PRODUCTS
- 2.1 PIPES AND TUBES (See Material Schedule on sheet P010 for where these materials are to be used)
- A. Hard Copper Tube: ASTM B 88, Types L and M, water tube, drawn temper.
- 2.2 FITTINGS
- A. Wrought Copper, Solder Joint Pressure Fittings: ASME B 16.22.
- B. Cast Copper Alloy, Solder Joint Pressure Fittings: ASME B 16.18.
- C. Bronze Flanges: ASME B 16.24, Classes 150 and 300.
- D. Copper Unions: ASME B 16.18, cast copper alloy body, hexagonal stock, with ball and socket joint, metal to metal seating surfaces, and solder joint, threaded, or solder joint and threaded ends. Threads complying with ASME B 1.20.1.
- E. Copper and Copper Alloy Press-Connect Pressure Fittings: Copper Press Fittings: ASME B16.51
- 2.3 JOINING MATERIALS
- A. Solder Filler Metal: ASTM B 32, lead free.
- B. Brazing Filler Metals: AWS A5.8, alloys to suit system requirements.
- C. Solvent Cements: As recommended by manufacturer.
- D. Plastic Pipe Seals: ASTM F 477, elastomeric gasket.
- PART 3 - EXECUTION
- 3.1 VALVE APPLICATIONS
- A. Install gate valves close to main on each branch and riser serving two or more plumbing fixtures or equipment connections and where indicated.
- B. Install gate or ball valves on inlet to each plumbing equipment item, on each supply to each plumbing fixture not having stops on supplies, and elsewhere as indicated.
- C. Install drain valve at base of each riser, at low points of horizontal runs, and where required to drain water distribution piping system.
- D. Install swing check valve on discharge side of each pump and elsewhere as indicated.
- E. Install ball valves in each hot water circulating loop and discharge side of each pump.
- 3.2 PIPING INSTALLATIONS
- A. Install hangers and supports at intervals indicated in the applicable plumbing code and as recommended by pipe manufacturer.
- B. Support vertical piping at each floor.
- 3.3 INSPECTING AND CLEANING
- A. Inspect and test piping systems following procedures of authorities having jurisdiction.
- B. Clean and disinfect water distribution piping following procedures of authorities having jurisdiction.
- END OF SECTION 15140

SECTION 15150 - SANITARY WASTE AND VENT PIPING

- PART 1 - GENERAL
- 1.1 SECTION REQUIREMENTS
- A. Minimum Pressure Requirement for Soil, Waste and Vent: 10 feet head.
- B. Comply with NSF 14 "Plastic Piping Components and Related Materials".
- PART 2 - PRODUCTS
- 2.1 PIPES AND TUBES
- A. PVC Plastic, DWV Pipe: ASTM D 2665, Schedule 40, plain ends.
- 2.2 FITTINGS
- A. PVC Plastic, DWV Pipe Fittings: ASTM D 2665, made to ASTM D 3311; socket type; drain, waste, and vent pipe patterns.
- PART 3 - EXECUTION
- 3.1 PIPING INSTALLATION
- A. Install cleanout and extension to grade at connection of building sanitary drain and building sanitary sewer.
- B. Locate drainage piping runouts as close as possible to bottom of floor slab supporting fixtures or drains.
- 3.2 INSPECTION
- A. Inspect and test piping systems following procedures of authorities having jurisdiction.
- END OF SECTION 15150

SECTION 15198 - NATURAL GAS PIPING

- PART 1 - GENERAL
- 1.1 SECTION REQUIREMENTS
- A. Quality Assurance: Comply with NFPA 54 and the Plumbing Code.
- PART 2 - PRODUCTS
- 2.1 PIPE, TUBE, AND SPECIALTIES
- A. Steel Pipe: ASTM A 53, Type S (Seamless), Grade B, Schedule 40, plain ends.
- 2.2 FITTINGS
- B. Fittings:
- a. Malleable Iron Threaded Fittings: ASME B16.3, Class 150.
 - b. Cold Press Mechanical Joint Fitting System: Viega MegaPress
- C. Manual Valves: Comply with standards listed or, if appropriate, to ANSI Z21.15.
- D. Gas Stops: AGA certified, bronze-body, plug type with bronze plug; for 2-psig or less natural gas. Include AGA stamp, flat or square head or lever handle, and threaded ends complying with ASME B1.20.1.
- E. Gas Valves: 150-psig WOG, cast-iron or bronze body, bronze plug, straightaway pattern, square head, tapered-plug type.
- F. Gas Pressure Regulators: ANSI Z21.18, single stage, steel jacketed, corrosion resistant pressure regulators. Include atmospheric vent, elevation compensator. Regulator pressure ratings, inlet and outlet pressures, and flow volume in cubic feet per hour of natural gas at specific gravity are as indicated.
- G. Line Gas Pressure Regulators: Inlet pressure rating not less than system pressure.
- H. Flexible Connectors: ANSI Z21.24, copper alloy.
- I. Strainers: Bronze body, Y-pattern, full size of connecting piping. Include stainless-steel screens with 3/64 inch perforations and a pressure rating of 125-psig- minimum, WOG working pressure.
- PART 3 - EXECUTION
- 3.1 INSTALLATION
- A. Close equipment shutoff valves before turning off gas to premises or section of piping. Perform leakage test as specified to determine that all equipment is turned off in affected piping section.
- B. Install shutoff valve, downstream from gas meter, outside building at gas service entrance.
- C. Install gas stops for shutoff to appliances with NPS 2" or smaller low pressure gas supply.
- D. Drips and Sediment Traps: Install drips at points where condensate may collect. Include outlets of gas meters. Locate where readily accessible to permit cleaning and emptying. Do not install where condensate would be subject to freezing.
- E. Install gas piping at uniform slope of 0.1 percent upward toward risers.
- F. Connect branch piping from top or side of horizontal piping.
- G. Install strainers on supply side of each control valve, gas pressure regulator, solenoid valve, and elsewhere as indicated.
- H. Install valves in accessible locations, protected from damage.
- I. Install gas valve upstream from each gas pressure regulator. Where two gas-pressure regulators are installed in series, valve is not required at second regulator.
- J. Connect gas piping to equipment and appliances with shutoff valves and unions. Install gas valve upstream from and within 36 inches of each appliance using gas. Install union or flanged connection downstream from valve.
- K. Inspect, test, and purge piping according to NFPA 54, Part 4, "Gas Piping Inspection, Testing, and Purging", and requirements of authorities having jurisdiction.
- END OF SECTION 15198

SECTION 15410 - PLUMBING FIXTURES

- PART 1 - GENERAL
- 1.1 SECTION REQUIREMENTS
- Submittals: None.
- A. Comply with requirements of Public Law 102-486, "Energy Policy Act", regarding water flow rate and water consumption of plumbing fixtures.
- B. Comply with applicable standards below:
1. Enameled, Cast Iron Fixtures: ASME A112.19.1M.
 2. National Sanitation Foundation Construction: NFS2.
 3. Porcelain Enameled Fixtures: ASME A112.19.4M.
 4. Slip Resistant Bathing Surfaces: ASTM F 462.
 5. Stainless Steel Fixtures: ASME A112.19.3M.
 6. Vitreous China Fixtures: ASME A112.19.2M.
- PART 2 - PRODUCTS
- 2.1 Refer to the fixture schedule on drawing P600
- PART 3 - EXECUTION
- 3.1 INSTALLATION
- A. Install fixtures with flanges and gasket seals.
- B. Install flushometer valves for accessible water closets and urinals with handle mounted on wide side of compartment. Install other actuators in locations that are easy for the disabled to reach.
- C. Fasten wall hanging plumbing fixtures securely to supports attached to building substrate when supports are specified, and to building wall construction where no support is indicated.
- D. Fasten floor mounted fixtures to substrate. With fixtures having holes for securing fixture to wall construction, fasten to reinforcement built into walls.
- E. Fasten wall mounted fittings to reinforcement built into walls.
- F. Fasten counter mounted plumbing fixtures to casework.
- G. Secure supplies to supports or substrate within pipe space behind fixture.
- H. Set mop basins in leveling bed of cement gROUT.
- I. Install individual supply inlets, supply stops, supply risers, and tubular brass traps with cleanouts at fixture.
- J. Install water supply stop valves in accessible locations.
- K. Install traps on fixture outlets. Omit traps on fixtures having integral traps. Omit traps on indirect wastes, unless otherwise indicated or required by the Authority Having Jurisdiction.
- L. Install full-ring escutcheons at wall, floor, and ceiling penetrations in exposed, finished locations and within cabinets and millwork. Use deep pattern escutcheons where required to conceal protruding pipe fittings.
- M. Install piping connections between plumbing fixtures and piping systems and plumbing equipment. Install insulation on supplies and drains of fixtures for the disabled.
- N. Ground equipment. Tighten electrical connectors and terminals according to UL 486A and UL 486B.
- END OF SECTION 15410

SECTION 15554 - FLUES AND VENTS

- PART 1 - GENERAL
- 1.1 SECTION REQUIREMENTS
- A. Submittals: None.
- PART 2 - PRODUCTS
- 2.1 GAS VENTS
- A. Vent/air intake for high efficiency domestic water heater. Follow manufacturer's recommendations for sizing and material.
- B. Accessories: Tees, elbows, increasers, draft hood connectors, metal cap with bird barrier, adjustable roof flashing, storm collar, support assembly, thimbles, firestopping spacers, and fasteners; fabricated of similar materials and designs as vent-pipe straight sections.
- PART 3 - EXECUTION
- 3.1 INSTALLATION
- A. Install vents according to stipulated minimum clearances from combustibles.
- B. Seal between sections of positive pressure vents using only sealants recommended by manufacturer.
- C. Support vents at intervals to support the weight of the vent and all accessories, without exceeding loading of appliances.
- END OF SECTION 15554

PLUMBING GENERAL NOTES

- A. GENERAL NOTES APPLY TO PLUMBING SHEETS.
- B. PLUMBING WORK SHALL BE DONE IN ACCORDANCE WITH THE PLUMBING CODE, LOCAL HEALTH DEPARTMENT STANDARDS, AND THE AUTHORITY HAVING JURISDICTION. SEE ARCHITECTURAL SHEETS FOR THE PREVAILING CODES.
- C. PIPING LAYOUTS ON DRAWINGS ARE SCHEMATIC. EXACT LOCATIONS ARE TO BE COORDINATED WITH THE EXISTING CONDITIONS AND THE WORK OF OTHER TRADES.
- D. CONCEAL PIPING UNLESS NOTED OTHERWISE. WATER SUPPLY PIPES SHALL BE INSTALLED LEVEL.
- E. PROVIDE SHUT-OFF VALVES FOR ISOLATION OF FIXTURE GROUPS AS SHOWN ON DRAWINGS IN ADDITION TO STOP VALVES AT EACH FIXTURE.
- F. PROVIDE STOP VALVES AT FIXTURES.
- G. PROVIDE TRAP PRIMERS FOR FLOOR DRAINS.
- H. WHERE THE WATER OR GAS SUPPLY LINE SIZE SHOWN IN THE PLUMBING DIAGRAMS DIFFERS FROM THE FIXTURE OR EQUIPMENT CONNECTION SIZE, PROVIDE LINE SIZE PIPE TO WITHIN 6" OF THE FIXTURE OR EQUIPMENT BEFORE TRANSITIONING TO THE CONNECTION SIZE.
- I. PIPING IN EXTERIOR WALLS SHALL BE INSTALLED BETWEEN THE INSULATION AND THE INTERIOR WALL FINISHING MATERIAL.
- J. INSULATE THE HOT AND COLD WATER, CONDENSATE DRAINAGE, AND STORM PIPING PER THE SPECIFICATIONS AND DETAIL 8/P700.
- K. PROVIDE GAS SHUT-OFF VALVES AT EACH PIECE OF EQUIPMENT. PROVIDE ACCESSIBLE DIRT LEG AT THE BOTTOM OF VERTICAL SECTIONS OF GAS PIPE AND AT THE CONNECTION TO EACH PIECE OF EQUIPMENT.
- L. PLUMBING FIXTURES, ACCESSORIES, AND MATERIALS PROVIDED FOR DOMESTIC WATER SHALL BE LEAD FREE.
- M. PRIOR TO TURNOVER PERFORM A VIDEO INSPECTION OF THE SANITARY AND GREASE LINES FROM THE MAIN LINES WITHIN THE TENANT SPACE TO THE MAIN SEWER TO VERIFY THAT THE SANITARY WASTE SYSTEM IS CONNECTED, CLEAN, AND FREE OF SAGS, BELRIES, BREAKS, AND DEBRIS. DELIVER A REPORT AND COPY OF THE VIDEO TO THE TENANT'S CONSTRUCTION MANAGER PRIOR TO TURNOVER.
- N. THE TERM "FURNISH" MEANS SUPPLY AND DELIVER TO THE PROJECT SITE, READY FOR UNLOADING, UNPACKING, ASSEMBLY, INSTALLATION, AND SIMILAR OPERATIONS. THE TERM "INSTALL" DESCRIBES THE OPERATIONS AT THE PROJECT SITE INCLUDING THE ACTUAL UNLOADING, UNPACKING, ASSEMBLY, ERECTING, PLACING, ANCHORING, APPLYING, WORKING TO DIMENSION, FINISHING, CURING, PROTECTING, CLEANING, AND SIMILAR OPERATIONS. THE TERM "PROVIDE" MEANS TO FURNISH AND INSTALL, COMPLETE AND READY FOR THE INTENDED USE.
- O. PRIOR TO CONNECTION TO ANY EXISTING SEWER SYSTEM PERFORM A DIE TEST TO VERIFY THE TYPE OF SYSTEM AND THE DIRECTION OF FLOW. REPORT ANY DEVIATION FROM THE CONSTRUCTION DOCUMENTS TO THE TENANT'S CONSTRUCTION MANAGER.
- P. PROVIDE SANITARY AND GREASE WASTE PIPES AT A MINIMUM SLOPE OF 1/4" PER FOOT UNLESS NOTED OTHERWISE.

PLUMBING SYMBOLS

	ELBOW UP
	ELBOW DOWN
	DOMESTIC COLD WATER
	DOMESTIC FILTERED COLD WATER
	DOMESTIC SOFTENED COLD WATER
	DOMESTIC HOT WATER (110 DEGREES)
	DOMESTIC HOT WATER RECIRC.
	GAS
	GAS (ON ROOF)
	SANITARY WASTE
	GREASE WASTE
	SANITARY VENT
	CONDENSATE DRAIN
PLAN NOTE: SEE PLAN NOTES LISTED ON THE SAME SHEET FOR NOTE MEANING	
	CONNECT TO EXISTING
	REDUCED PRESSURE ZONE BACKFLOW PREVENTER
	WATER METER
	GAS METER
	EQUIPMENT TAG; SEE EQUIPMENT SCHEDULE ON SHEET P600 FOR EQUIPMENT INFORMATION
	VALVE
	SOLENOID-OPERATED VALVE
	WALL HYDRANT/ROOF HYDRANT
	CHECK VALVE
	CIRCUIT-SETTER BALANCE VALVE RATED FOR POTABLE WATER
	FLOOR DRAIN
	FLOOR SINK
	CLEANOUT

PLUMBING ABBREVIATIONS

AFF	ABOVE FINISHED FLOOR
AFG	ABOVE FINISHED GRADE
(E)	EXISTING
EXT'G	EXISTING
FCO	FLOOR CLEANOUT
FD	FLOOR DRAIN
FS	FLOOR SINK
GCO	GRADE CLEANOUT

CO2AS	TENANT'S CO2 ALARM SUPPLIER
GC	GENERAL CONTRACTOR
HES	TENANT'S HVAC EQUIPMENT SUPPLIER
HS	TENANT'S HOOD SUPPLIER
KES	TENANT'S KITCHEN EQUIPMENT SUPPLIER
TAB	TENANT'S TEST AND BALANCE VENDOR
TCC	TENANT'S CABLING CONTRACTOR
TDC	TENANT'S DUCT CLEANER
TEMS	TENANT'S ENERGY MANAGEMENT SYSTEM SUPPLIER
TLS	TENANT'S LIGHT/LAMP SUPPLIER
TMB	TENANT'S MENU BOARD SUPPLIER
TMS	TENANT'S MILLWORK SUPPLIER
TP	TENANT'S PHONE SUPPLIER
TPS	TENANT'S PANELBOARD SUPPLIER
TRS	TENANT'S RAILING SUPPLIER
TSV	TENANT'S SIGN VENDOR
TUV	TENANT'S UV SANITIZER SUPPLIER
WCS	TENANT'S WALK-IN COOLER SUPPLIER
WHS	TENANT'S WATER HEATER SUPPLIER

PLUMBING MATERIAL SCHEDULE		
CATEGORY	APPLICATION	ALLOWABLE MATERIAL
WATER SUPPLY PIPE	ABOVE GRADE	TYPE L COPPER TUBE
	CONCEALED	SCH. 40 STEEL PIPE, MALLEABLE IRON THREADED FITTINGS
NATURAL GAS PIPE	EXPOSED	SCH. 40 STEEL PIPE, MALLEABLE IRON THREADED FITTINGS, PAINTED
	ABOVE GROUND, CONCEALED	PVC PLASTIC DWV PIPE AND FITTINGS
SANITARY WASTE & VENT PIPE	ABOVE GROUND PREP SINK AND WARE WASHING SINK DRAINS	PVC PLASTIC DWV PIPE AND FITTINGS
	ABOVE GROUND HAND SINK DRAINS	BRASS WITH CHROME FINISH
	BELOW GROUND	PVC PLASTIC DWV PIPE AND FITTINGS

Consultant:



4635 Trueman Blvd. Suite 250
Hilliard, Ohio 43026
Phone: (614) 751-9610
Fax: (614) 552-5240
Contact: Cliff Kigar
(614) 328-2033
ckigar@nationalengineering.com

FOR CONSTRUCTION

COPYRIGHT 2024
THIS DRAWING IS AN INSTRUMENT OF SERVICE
AND AS SUCH REMAINS THE PROPERTY OF
CHIPOTLE MEXICAN GRILL, INC.. PERMISSION FOR
USE OF THIS DOCUMENT IS LIMITED AND CAN BE
EXTENDED ONLY BY WRITTEN AGREEMENT WITH
CHIPOTLE MEXICAN GRILL, INC..



CHIPOTLE MEXICAN GRILL, INC.
PO BOX 182566
COLUMBUS, OH 43218-2566
TELEPHONE: (614) 318-2400
INTERNET: WWW.CHIPOTLE.COM

STORE NO.: 4870

WALNUT HILLS, OH
1202 E. MCMILLAN
CINCINNATI, OH 45206

Issue Record:	PERMIT SET
11/03/2023	CONSTRUCTION SET
05/08/2024	

Revisions:	PLAN REVIEW COMMENTS
2	4/25/24

Drawn: Checked:

CLK JEJ

Project No.

2301004

Contents:

PLUMBING SPECIFICATIONS

P010

ROUGH-IN TYPE KEY	
ANGLE 3/8"	BRASS CRAFT KTR19 OR EQUAL (BRASS/CHROME 1/4 TURN ANGLED BALL STOP WITH 3/8" COMPRESSION CONNECTION)
ANGLE 1/2"	BRASS CRAFT R39X C OR EQUAL (BRASS/CHROME MULTI-TURN ANGLED STOP WITH 1/2" COMPRESSION CONNECTION)
ANGLE 3/4"	EVERFLOW 74342-NL W/ 3/4" SWEAT X MIP ADAPTER OR EQUAL (BRASS ANGLE STOP W/ 3/4" FIP INLET AND OUTLET)
DIRECT	PROVIDE COPPER PIPE IN CONNECTION SIZE SHOWN TO FIXTURE
HOSE 1/2"	ARROWHEAD BRASS WM50F OR EQUAL (BRASS/CHROME WASHING MACHINE VALVE W/ 3/4" MHT OUTLET)
MIP	PROVIDE PIPE WITH MIP THREAD STUBBED OUT OF WALL IN CONNECTION SIZE SHOWN AND LENGTH COMPATIBLE WITH FIXTURE AND WALL MATERIAL/FINISHES.

CONNECT TO THE EXISTING 1-1/2" DOMESTIC WATER SERVICE WITH EXISTING UPSTREAM METER AND BFP IN LANDSCAPING.

2 PROVIDE 1/2" FILTERED WATER TO THE BAG-IN-BOX SODA CARBONATOR AT 102" AFF. SODA CARBONATOR SHALL HAVE AN INTEGRAL ASSE 1022-RATED CARBONATED BEVERAGE BACKFLOW PREVENTION DEVICE.

3 PROVIDE WATER HEATER DWH-1 & DWH-2 PER DETAIL 1/P700.

4 PROVIDE WATER FILTERS MOUNTED TO WALL PER DETAIL 11/P700. PROVIDE 1/2" SUPPLY PIPES FROM FILTERS TO ICE MAKER AND SODA CARBONATOR AS SHOWN.

5 PROVIDE 1/2" FILTERED WATER ROUGH-IN TO THE ICE MAKER AT 56" AFF. PROVIDE 6" LONG STAINLESS STEEL FLEXIBLE BRAIDED WASHING MACHINE WATER CONNECTOR WITH MINIMUM 0.43" ID (BRASSCRAFT SL12-72WA F OR EQUAL) FOR FINAL CONNECTION TO ICE MAKER.

6 PROVIDE DOMESTIC WATER ROUGH-INS FOR THE MOP BASIN FAUCET AT 36" AFF. PROVIDE DOMESTIC WATER ROUGH-INS FOR THE CHEMICAL DISPENSER FAUCET (HB-1) AT 64" AFF DIRECTLY ABOVE THE MOP BASIN FAUCET. SEE ARCHITECTURAL ELEVATION FOR ADDITIONAL INFORMATION.

7 CONNECT TO THE EXISTING 2-1/2" GAS LINE IN LOCATION SHOWN WITH EXISTING UPSTREAM METER.

8 PROVIDE GAS CONNECTIONS TO THE COOKING EQUIPMENT PER DETAIL 7/P700.

9 SUPPORT THE GAS PIPE ON THE ROOF PER DETAIL 5/P700. WOOD BLOCKING IS NOT AN ACCEPTABLE METHOD OF SUPPORTING THE GAS PIPE.

10 PROVIDE ACCESSIBLE LINE-SIZED GAS VALVE, DIRT LEG, AND UNION AT GAS CONNECTION TO THE EQUIPMENT.

11 REFER TO ARCHITECTURAL DRAWINGS FOR PAINTING OF INTERIOR AND EXTERIOR EXPOSED GAS PIPE.

12 PROVIDE DOMESTIC WATER ROUGH-INS FOR THE CHEMICAL DISPENSER FAUCET (HB-1) AT 52" AFF. SEE ARCHITECTURAL ELEVATION FOR ADDITIONAL INFORMATION.

13 PROVIDE DOMESTIC WATER ROUGH-INS FOR THE VICTORY WASH DISPENSER FAUCET (HB-2) AT 52" AFF. SEE ARCHITECTURAL ELEVATION FOR ADDITIONAL INFORMATION.

14 PROVIDE ROUGH-INS TO RESTROOM HAND SINKS AS SHOWN IN DETAIL 14/P700.

15 PROVIDE KITCHEN EQUIPMENT GAS SHUTOFF 6" BELOW THE CEILING PER DETAIL 4/P700.

16 CONNECT CHEMICAL DISPENSER TO HB-1. CHEMICAL DISPENSER HAS AN INTEGRAL AIR GAP AS IS SHOWN IN DETAIL 10/P700.

17 PROVIDE ASSE 1016/1070 POINT-OF-USE THERMOSTATIC MIXING VALVE, WATTS LFUSG-B, ON WATER SUPPLY TO KITCHEN HAND SINKS. PROVIDE ANGLE STOP BELOW SINK, FASTEN MIXING VALVE TO WALL, AND MAKE FINAL CONNECTION FROM ANGLE STOPS TO MIXING VALVE AND FROM MIXING VALVE TO FAUCET USING BRAIDED STAINLESS STEEL HOSE. ADJUST MIXING VALVE FOR A DISCHARGE TEMPERATURE OF APPROXIMATELY 110° F.

18 PROVIDE ACCESSIBLE VALVE IN WATER SUPPLY TO FIXTURE AS SHOWN.

19 PROVIDE GAS CONNECTION TO THE RICE COOKER PER DETAIL 6/P700.

20 PROVIDE GAS ROUGH-IN TO FRYER BEHIND RICE COOKER TABLE SO THAT VALVES AND DIRT LEG ARE ACCESSIBLE ONCE FRYER IS SECURED INTO PLACE.

21 INSTALL RGF IM5B ICE MAKER SANITIZER FURNISHED BY TUV PER CHIPOTLE'S INSTALLATION INSTRUCTIONS.

23 PROVIDE 3/4" DOMESTIC HOT AND COLD WATER ROUGH-INS FOR THE PREP SINK (SK-2) FAUCET AT 24" AFF TO ALLOW FOR THE VICTORY WASH CHEMICAL DOCK TO BE INSTALLED DIRECTLY BELOW THE PREP SINK BASIN. MAKE FINAL CONNECTION TO PREP SINK FAUCET USING 3/4" BRAIDED STAINLESS STEEL WATER HEATER CONNECTOR HOSE.

24 PROVIDE 3/4" HOT WATER TO THE DISH MACHINE. MAKING FINAL CONNECTION USING CONNECTION HOSE FURNISHED WITH DISH MACHINE. PROVIDE WATER HAMMER ARRESTOR ON HOT WATER LINE. PROVIDE AN ACCESSIBLE SHUTOFF VALVE BELOW THE DISH MACHINE AND INSTALL THE STRAINER FURNISHED WITH THE DISH MACHINE IN AN ACCESSIBLE LOCATION AT THE CONNECTION TO THE UNIT.

25 PROVIDE ROOF HYDRANT RH-1 WITH BOTTOM OF NOZZLE INSTALLED 24" ABOVE THE BOTTOM OF ROOF DECK. PROVIDE ACCESSIBLE ISOLATION VALVE IN WATER SUPPLY TO ROOF HYDRANT. SUPPORT ROOF HYDRANT PER THE MANUFACTURER'S INSTALLATION INSTRUCTIONS.

26 PROVIDE FILTERED DOMESTIC WATER ROUGH-INS FOR THE SPEED FILL POT FILLER FAUCET (PF-1) AT 40" AFF. SEE ARCHITECTURAL ELEVATION FOR DETAIL.

27 PROVIDE 1/2" FILTERED WATER ROUGH-IN TO THE ICE MAKER AT 24" AFF. PROVIDE 6" LONG STAINLESS STEEL FLEXIBLE BRAIDED WASHING MACHINE WATER CONNECTOR WITH MINIMUM 0.43" ID (BRASSCRAFT SL12-72WA F OR EQUAL) FOR FINAL CONNECTION TO ICE MAKER.


28 INSTALL RGF IM5B ICE MAKER SANITIZER FURNISHED BY TUV PER CHIPOTLE'S INSTALLATION INSTRUCTIONS. LOCATE IM5B BELOW UTENSIL COUNTER IN A LOCATION THAT DOES NOT INTERFERE WITH THE ROLLING RACK BELOW THE UTENSIL COUNTER.

29 PROVIDE ACCESSIBLE TRAP PRIMER ABOVE LAY-IN CEILING AS SHOWN. INSTALL PER MANUFACTURER'S INSTALLATION INSTRUCTIONS WITH A SERVICE VALVE AT THE TRAP PRIMER INLET. PROVIDE 1/2" DISTRIBUTION PIPE(S) TO FLOOR DRAIN TRAP PRIMER CONNECTION(S) AS SHOWN. HORIZONTAL DISTRIBUTION PIPING SHALL HAVE CONTINUOUS SLOPE TO THE FLOOR DRAIN(S).

30 PROVIDE WATER SOFTENER AS SHOWN IN DETAIL 16/P700.

31 PROVIDE AN ACCESSIBLE MAIN DOMESTIC WATER SHUTOFF VALVE ABOVE LAY-IN CEILING AS SHOWN. VALVE SHALL BE 12" ABOVE THE TOP OF THE LAY-IN CEILING. PERMANENTLY INSTALL THE "WATER SHUTOFF" SIGN TO THE CEILING GRID BELOW THE VALVE.

NOTES:
1. PRESSURE REQUIRED AFTER METER: 7" W.C.
2. DISTANCES ARE APPROXIMATE

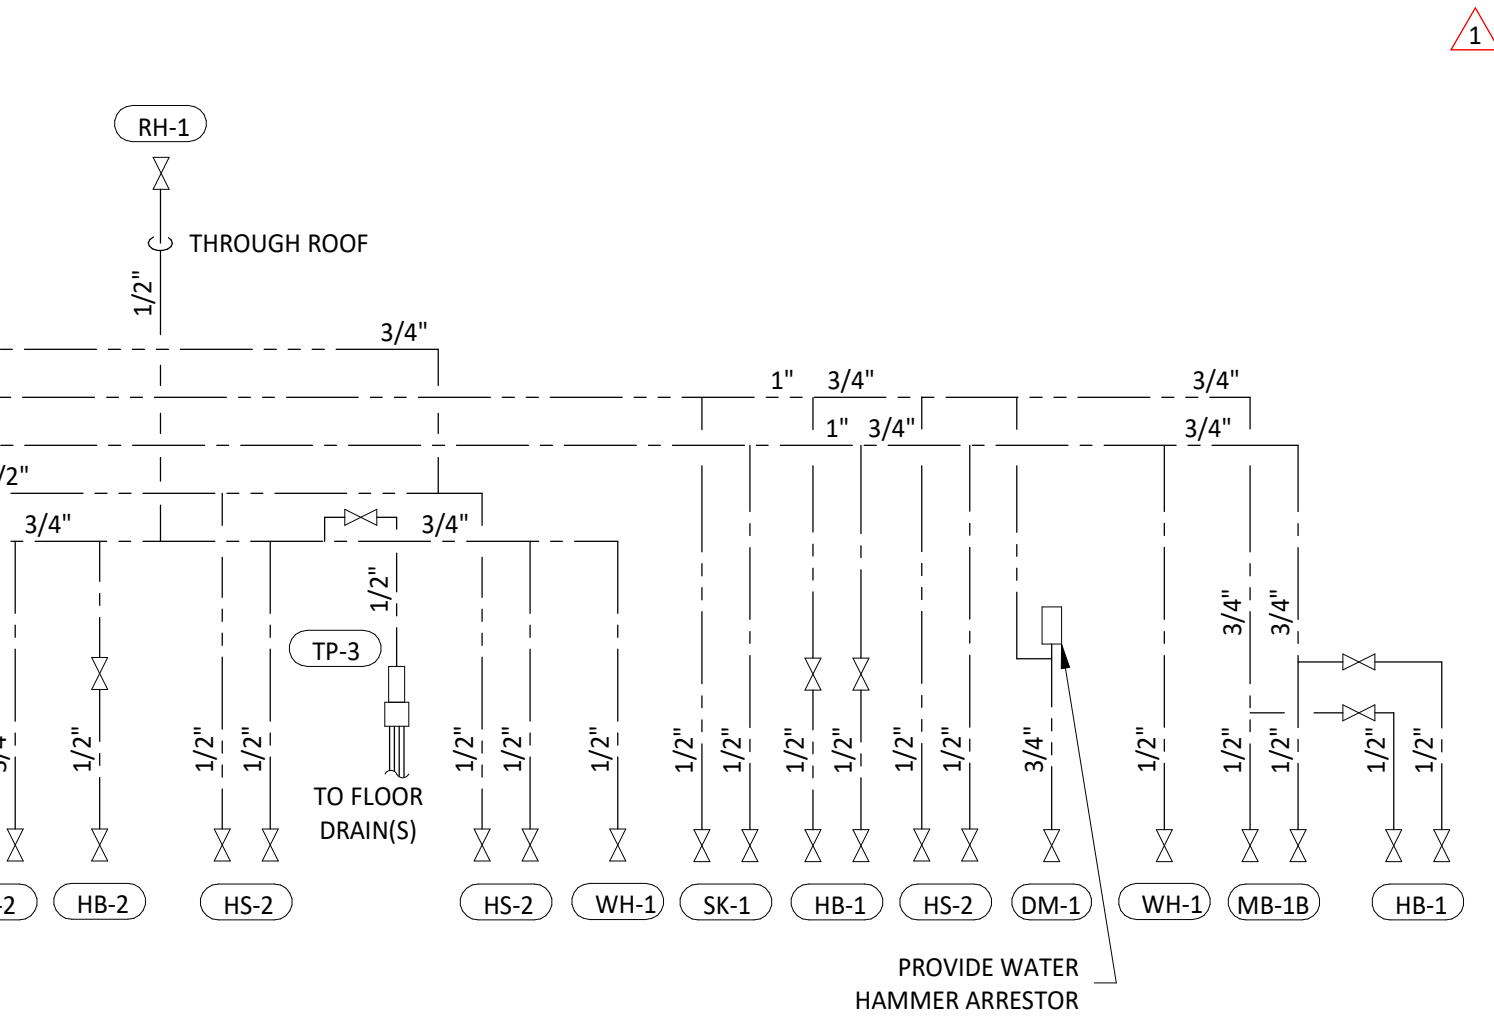


P100 N.T.S.




PLUMBING WASTE AND VENT PLAN NOTES

- 1 PROVIDE 3/4" CONDENSATE DRAIN FROM THE WALK-IN COOLER EVAPORATOR TO THE FLOOR SINK AS SHOWN. SLOPE CONDENSATE DRAIN A MINIMUM OF 1" PER FOOT. HOLD EXPOSED CONDENSATE DRAIN IN WALK-IN COOLER AS HIGH AS POSSIBLE. CONCEAL DRAIN PIPING WITHIN FRAMED WALLS AS SHOWN. DISCHARGE THROUGH AN AIR GAP. MAKE FINAL CONNECTION TO EVAPORATOR INSIDE WALK-IN COOLER USING A UNION. CONDENSATE DRAIN SHOULD PENETRATE WALL AT 8" AFF AND BE SECURED TO FLOOR.
- 2 PROVIDE DRAIN CONNECTIONS TO THE THREE COMPARTMENT SINK PER DETAIL 2/P700.
- 3 COORDINATE ROUTING OF SODA BUNDLES WITH COCA-COLA TECHNICIAN FROM BAG-IN-BOX AREA TO EACH SODA FOUNTAIN. OTHER THAN WITHIN THE WALLS DOWN TO THE DRYER BOX THE SODA BUNDLE SHALL BE ROUTED OVERHEAD WITHOUT CONDUIT. COORDINATE SUPPORT AND ROUTING OF THE SODA LINE BUNDLES WITH COCA-COLA TECHNICIAN DURING ROUGH IN AND PROVIDE NECESSARY SUPPORTS. SEE ARCHITECTURAL DRAWINGS FOR SODA BUNDLE TERMINATION LOCATION AND PROVIDE TERMINATION PER DETAIL 12/P700.
- 4 PROVIDE PVC DRAIN PIPES FROM THE ICE MACHINE TO THE FLOOR SINK PER THE MANUFACTURER'S INSTALLATION INSTRUCTIONS. PROVIDE A CODE-APPROVED AIR GAP AT THE DISCHARGE TO THE FLOOR SINK. SECURE ICE MAKER DRAIN PIPES TO THE BOTTOM OF THE ICE MAKER.
- 5 PROVIDE DRAIN LINES FROM THE FOOD PREP SINK TO THE FLOOR SINK. PROVIDE AN AIR GAP AT THE DISCHARGE TO THE FLOOR SINK.
- 6 PROVIDE A 3" VENT THROUGH THE ROOF PER DETAIL 3/P700.
- 7 CONNECT TO EXISTING 4" GREASE WASTE LINE LEADING TO EXISTING DEDICATED 1500 GALLON INTERCEPTOR.
- 8 CONNECT TO EXISTING 4" SANITARY SEWER.
- 9 PROVIDE 3/4" VALVED DRAIN FROM HOT FOOD TABLE TO THE FLOOR SINK. DRAIN THROUGH AN AIR GAP.
- 10 PROVIDE INSULATED COPPER DRAIN LINES FROM THE TEA TRAY DRAIN AND THE SODA MACHINE DRAIN TO THE FLOOR SINK. DRAIN THROUGH AN AIR GAP. HOLD TEA TRAY DRAIN AS HIGH AS POSSIBLE AND SECURE TO STRUCTURE BELOW THE UTENSIL COUNTER.
- 11 TRIM TRENCH DRAIN ENDS PER THE MANUFACTURER'S INSTALLATION INSTRUCTIONS PRIOR TO INSTALLATION SO THAT GRATE FITS WITHOUT GAPS. INSTALL TRENCH DRAIN WITH SLIGHT POSITIVE SLOPE TOWARD THE DRAIN CONNECTION TO AVOID STANDING WATER IN TRENCH DRAIN.
- 12 SEE DETAIL 17/P700 FOR DRAINS FROM TEA TRAY, ICE MAKER, AND SODA MACHINE TO FUNNEL DRAIN.
- 13 DO NOT PROVIDE WALL CLEANOUTS ON TILE OR PUBLICLY-VISIBLE WALLS. IF A WALL CLEANOUT IS REQUIRED ON THESE SURFACE COORDINATE THE EXACT LOCATION WITH CHIPOTLE'S CONSTRUCTION MANAGER.
- 14 PROVIDE INDIRECT WASTE AND CONDENSATE DRAINS FROM FIXTURES OTHER THAN KITCHEN SINKS CONCEALED IN THE WALL AS SHOWN IN DETAIL 9/P700.
- 15 PROVIDE DRAIN FROM WATER FILTER BFP TO FLOOR DRAIN CONCEALED IN THE WALL AS SHOWN IN DETAIL 9/P700.
- 16 PROVIDE TRENCH DRAIN AS SHOWN IN DETAIL 15/P700.
- 17 INSTALL DRAIN HOSE FURNISHED WITH DISH MACHINE FROM DISH MACHINE OUTLET TO FLOOR SINK. HOLD DRAIN HOSE TIGHT TO WALL AND SECURE TO 3-COMP SINK DRAIN TO MAINTAIN AN AIR GAP AT THE FLOOR SINK.
- 18 PROVIDE CONDENSATE TRAP ON RTU PER DETAIL 13/P700.
- 19 PROVIDE 3/4" PVC DRAIN PIPE FROM THE ICE MACHINE TO THE FLOOR SINK PER THE MANUFACTURER'S INSTALLATION INSTRUCTIONS. PROVIDE A CODE-APPROVED AIR GAP AT THE DISCHARGE TO THE FLOOR SINK.

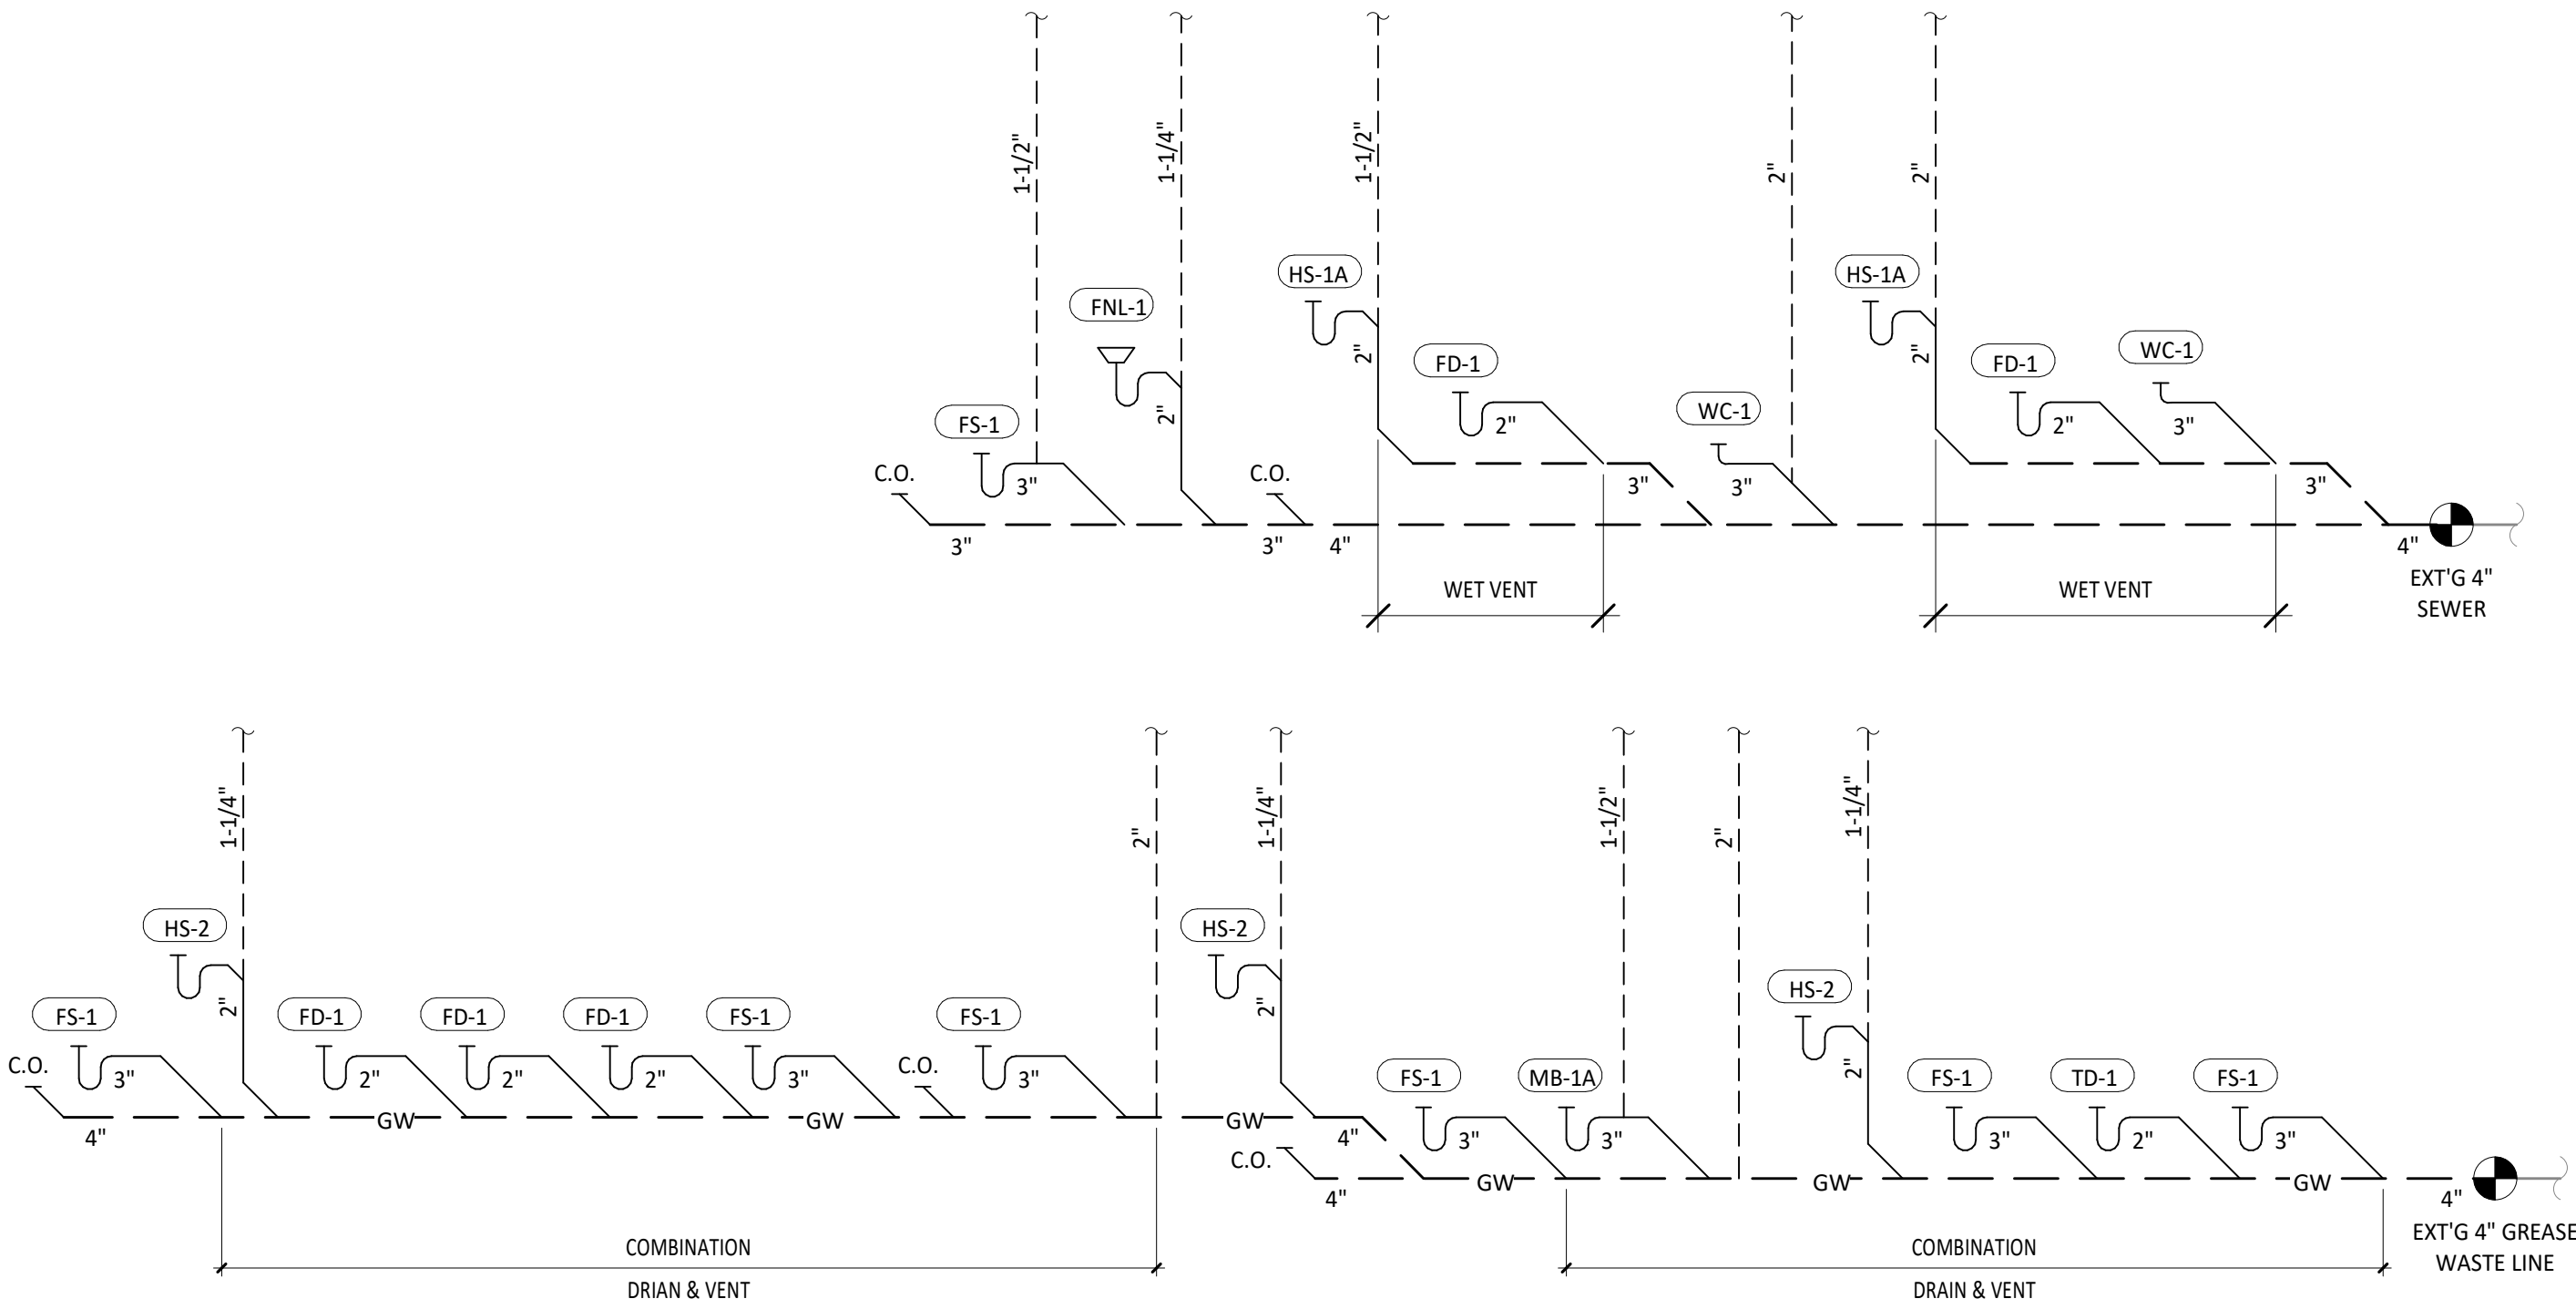

2 SANITARY WASTE & VENT DIAGRAM
P110 N.T.S.

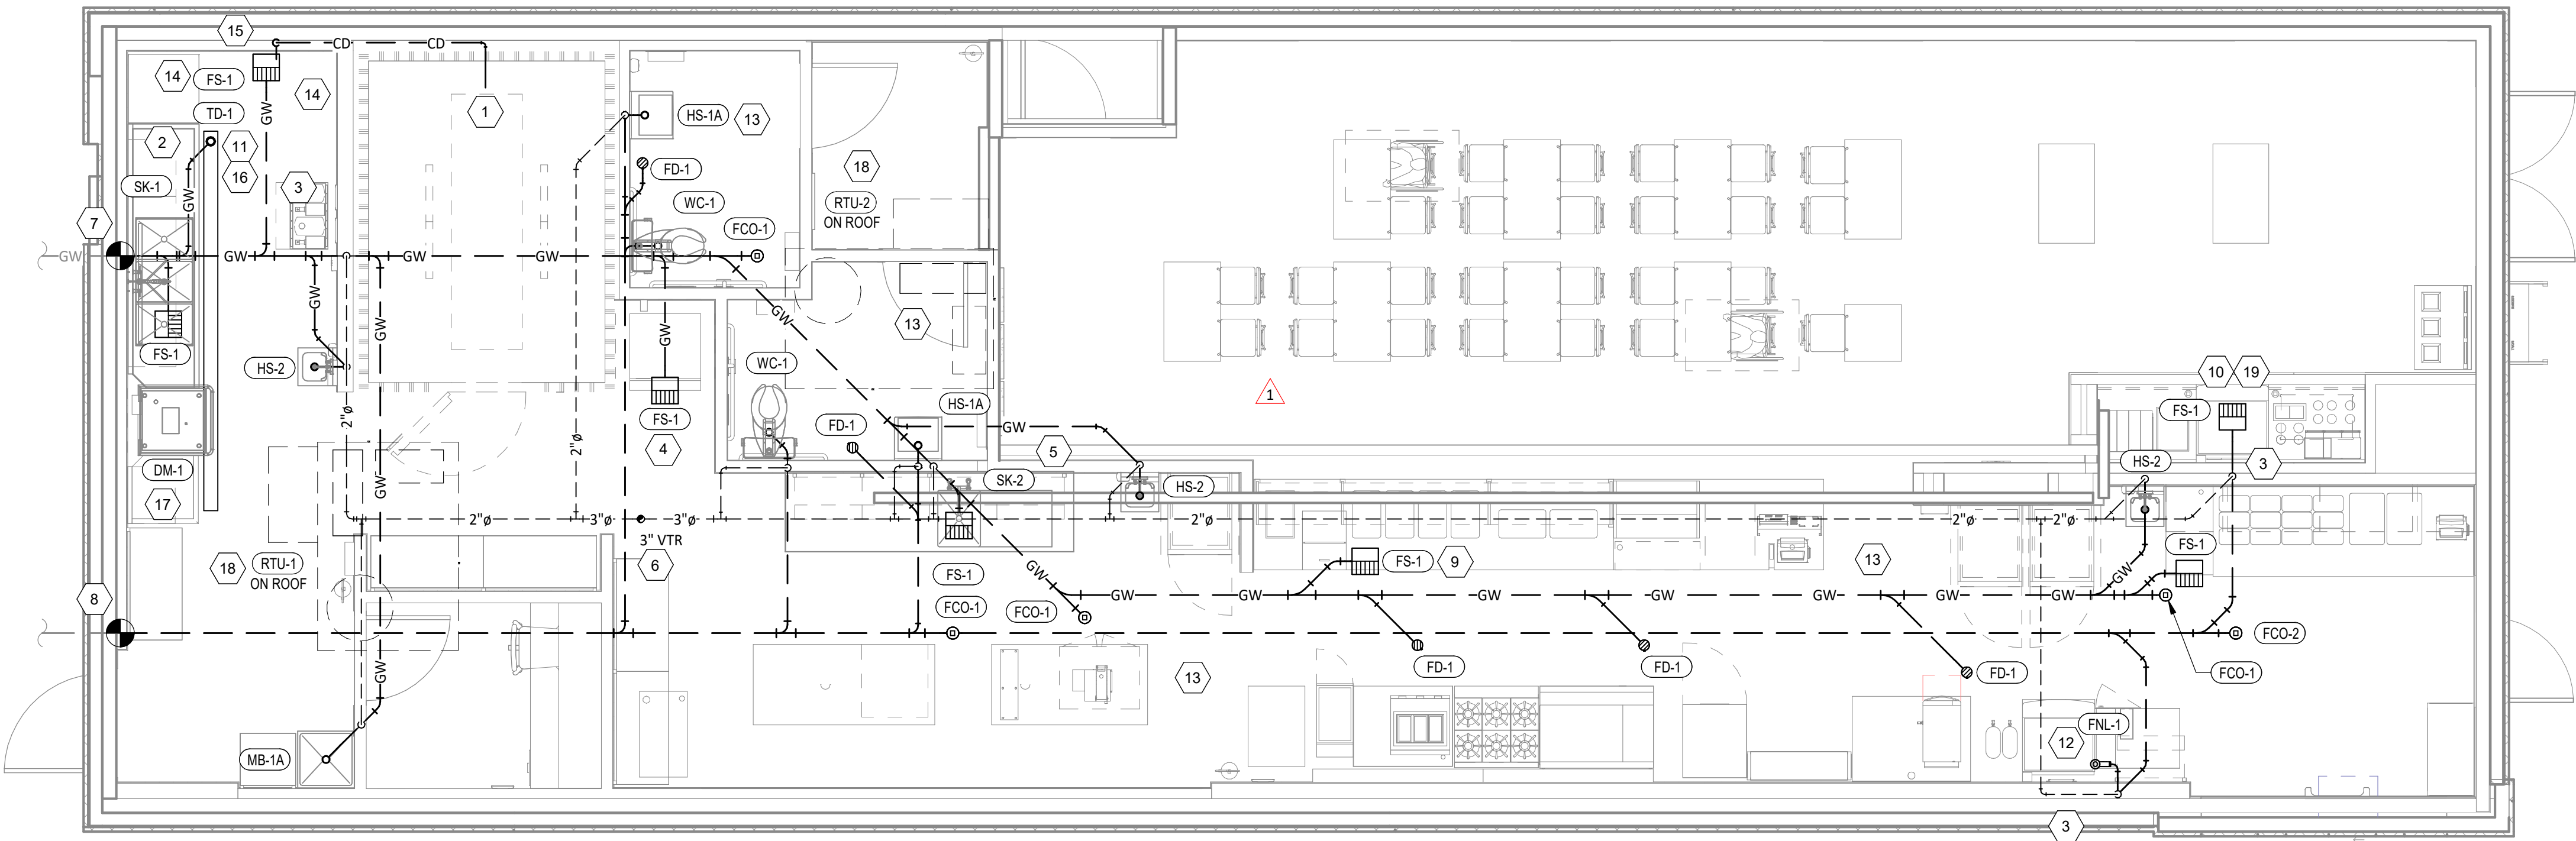

1 SANITARY WASTE & VENT PLAN
P110 1/4" = 1'-0"

Consultant:

NATIONAL
ENGINEERING
4635 Trueman Blvd, Suite 250
Hilliard, Ohio 43026
Phone: (614) 751-9610
Fax: (614) 552-5240
Contact: Cliff Kigar
(614) 328-2033
ckigar@nationalengineering.com

FOR CONSTRUCTION

COPYRIGHT 2024
THIS DRAWING IS AN INSTRUMENT OF SERVICE
AND AS SUCH REMAINS THE PROPERTY OF
CHIPOTLE MEXICAN GRILL, INC.. PERMISSION FOR
USE OF THIS DOCUMENT IS LIMITED AND CAN BE
EXTENDED ONLY BY WRITTEN AGREEMENT WITH
CHIPOTLE MEXICAN GRILL, INC..



CHIPOTLE MEXICAN GRILL, INC.
PO BOX 182566
COLUMBUS, OH 43218-2566
TELEPHONE: (614) 318-2400
INTERNET: WWW.CHIPOTLE.COM

STORE NO.: 4870
WALNUT HILLS, OH
1202 E. MCMILLAN
CINCINNATI, OH 45206

Issue Record:
11/03/2023 PERMIT SET
05/08/2024 CONSTRUCTION SET

Revisions:
1 1/24/24 HEALTH COMMENTS
2 4/25/24 PLAN REVIEW COMMENTS

Drawn: CJK
Checked: JEJ

Project No.
2301004

Contents:
PLUMBING PLAN
WASTE & VENT

P110

PLUMBING FIXTURE SCHEDULE

TAG	FIXTURE	FURNISHED BY	INSTALLED BY	MANUFACTURER	MODEL	DESCRIPTION	QUANTITY	CONNECTION SIZES			FIXTURE UNITS (EACH)				FIXTURE UNITS (TOTAL)			
								CW	HW	WASTE	CW	HW	TOTAL	SAN	CW	HW	TOTAL	SAN
BFP-1	RPZ BACKFLOW PREVENTER	GC	GC	CONBRACO	4ALF-203-T2F	LEAD FREE REDUCED PRESSURE PRINCIPLE BACKFLOW PREVENTER WITH AUTOMATIC DIFFERENTIAL RELIEF VALVE	1	1/2"			1		1		1	0	1	0
DM-1	DISH SANITIZING MACHINE (PUMPED OUTLET)	KES	GC	FURNISHED BY KES	--	CHEMICAL SANITIZING DISH MACHINE WITH INTEGRAL ELECTRIC BOOSTER HEATER AND PUMPED OUTLET	1		3/4"	3/4"	0	1	1	0	0	1	1	0
ET-1	EXPANSION TANK	GC	GC	AMTROL	ST-5	2 GALLON CAPACITY	1	3/4"			0	0	0	0	0	0	0	0
FCO-1	FLOOR CLEANOUT (4")	GC	GC	SIOUX CHIEF	852-4PNR	ON-GRADE ADJUSTABLE CLEANOUT WITH INTERNAL THREADED CLEANOUT PLUG AND ROUND NICKEL-BRONZE RING AND COVER (OR APPROVED EQUAL WITH INTERNAL THREADED CLEANOUT PLUG)	4			4"				0	0	0	0	0
FCO-2	FLOOR CLEANOUT (3")	GC	GC	SIOUX CHIEF	852-3PNR	ON-GRADE ADJUSTABLE CLEANOUT WITH INTERNAL THREADED CLEANOUT PLUG AND ROUND NICKEL-BRONZE RING AND COVER (OR APPROVED EQUAL WITH INTERNAL THREADED CLEANOUT PLUG)	1			3"				0	0	0	0	0
FD-1	FLOOR DRAIN	GC	GC	SIOUX CHIEF	842-2-PNR	ADJUSTABLE FLOOR DRAIN, ROUND POLISHED METAL RING AND STRAINER	5			2"			0	2	0	0	0	10
FNL-1	FUNNEL DRAIN	GC	GC	JAY R. SMITH	3832T	FUNNEL DRAIN WITH CAST BRONZE BODY AND THREADED OUTLET	1			2"	0	0		2	0	0	0	2
FS-1	FLOOR SINK	GC	GC	SIOUX CHIEF	861-3PU2	HEAVY DUTY PVC FLOOR SINK WITH ALUMINUM DOME BOTTOM STRAINER AND OPEN HALF PVC GRATE	7			3"			0	5	0	0	0	35
HB-1	HOSE BIBB	KES	GC	T&S	B-2345-01-KX	COMMERCIAL QUALITY HOT & COLD MIXING WALL HYDRANT. SUPPLY ARMS SHALL HAVE INTEGRAL SHUT-OFF STOP AND CHECK VALVE.	2	1/2"	1/2"		1.5	1.5	2	0	3	3	4	0
HB-2	HOSE BIBB	KES	GC	T&S	B-0730	SILL FAUCET WITH 1/2" NPT FEMALE INLET AND 3/4" GARDEN HOSE THREADED OUTLET.	1	1/2"			1.5	0	1.5	0	1.5	0	1.5	0
HS-1A	RESTROOM HAND SINK	GC	GC	KOHLER	K-2084	ADA-ACCESSIBLE, WALL-MOUNTED, PORCELAIN LAVATORY. PROVIDE ZURN Z1231 (Z1231-D FOR BACK-TO-BACK APPLICATIONS) CONCEALED ARM CARRIER IN WALL.	2	0"	0"	2"	0	0	0	1	0	0	0	2
HS-1B	RESTROOM HAND SINK FAUCET	KES	GC	FURNISHED BY KES	--	PLUG-IN AUTOMATIC FAUCET WITH 0.5 GPM AERATOR AND THERMOSTATIC MIXING VALVE. ADJUST FAUCET CONTROLS FOR 10 SECOND SHUTOFF DELAY AND 30 SECOND TIME-OUT DELAY.	2	1/2"	1/2"	0"	1.5	1.5	2	0	3	3	4	0
HS-2	KITCHEN HAND SINK	KES	GC	FURNISHED BY KES	--	STAINLESS STEEL SINK WITH WALL MOUNTING BRACKET AND BACKSPASH MOUNTED FAUCET WITH SWIVEL GOOSENECK	3	1/2"	1/2"	2"	1.5	1.5	2	1	4.5	4.5	6	3
IM-1	ICE MAKER - BOH	KES	GC	SEE ARCH	--	BACK OF HOUSE ICE MAKER WITH BIN	1	1/2"			1	0	1	0	1	0	1	0
IM-2	ICE MAKER - SODA	KES	KES	SEE ARCH	--	SODA MACHINE-MOUNTED ICE MAKER	2	1/2"			1		1		2	0	2	0
MB-1A	MOP BASIN	GC	GC	FIAT	MSB2424	PROVIDE 24"x24"x10" MOLDED-STONE MOP BASIN. INSTALL MOP BASIN IN A BED OF GROUT SO THERE ARE NO VOIDS BETWEEN THE MOP BASIN AND THE SLAB.	1	0"	0"	3"	0	0	0	3	0	0	0	3
MB-1B	MOP BASIN FAUCET	KES	GC	FURNISHED BY KES	--	SERVICE SINK FAUCET WITH BUILT IN STOPS, LEVER HANDLES, AND WALL BRACE.	1	1/2"	1/2"	0"	2.25	2.25	3	0	2.25	2.25	3	0
PF-1	POT FILLER	KES	GC	FURNISHED BY KES	--	WALL-MOUNTED POT FILLER W/ SELF-CLOSING FILLER VALVE AND 3/8" NPT FEMALE INLET	1	1/2"			1.5	0	1.5		1.5	0	1.5	0
RH-1	FREEZE PROOF ROOF HYDRANT	GC	GC	HOEPTNER	2131R	AUTOMATIC DRAINING, FREEZELESS ROOF HYDRANT WITH ANTI-SIPHON VACUUM BREAKER HOEPTNER PRODUCTS (408) 847-7615	1	3/4"			1	0	1		1	0	1	0
SK-1	THREE COMPARTMENT SINK	KES	GC	FURNISHED BY KES	--	THREE-COMPARTMENT WARE-WASHING SINK FURNISHED WITH (1) PRE-RINSE UNIT WITH ADD-ON FAUCET	1	1/2"	1/2"	2"	4	4	4	5	4	4	4	5
SK-2	PREP SINK	KES	GC	FURNISHED BY KES	--	STAINLESS STEEL PREP TABLE WITH INTEGRAL PREP SINK. FURNISHED WITH "BIG FLO" FAUCET	1	3/4"	3/4"	2"	3	3	4	0	3	3	4	0
TD-1	TRENCH DRAIN	GC	GC	ZURN	Z886 8601 8602	6" X 160" HDPE TRENCH DRAIN (SLOPED FROM 3.50" TO 4.70") WITH (2) CLOSED END CAPS, (1) 4" NO-HUB BOTTOM OUTLET, AND CLASS-A HEEL-PROOF POLYETHYLENE GRATES. SEE DETAIL 12/P700 FOR REDUCTION TO 2" DRAIN CONNECTION.	1			2"	0	0	0	2	0	0	0	2
TP-2	TRAP PRIMER (TWO FLOOR DRAINS)	GC	GC	PRECISION PLUMBING PRODUCTS	P2-500 W/ DU-U	TRAP PRIMER WITH INTEGRAL VACUUM BREAKER AND DISTRIBUTION UNIT. CAP UNUSED DISTRIBUTION UNIT OUTLETS.	1	1/2"			0		0		0	0	0	0
TP-3	TRAP PRIMER (THREE-FOUR FLOOR DRAINS)	GC	GC	PRECISION PLUMBING PRODUCTS	P1-500 W/ DU-U	TRAP PRIMER WITH INTEGRAL VACUUM BREAKER AND DISTRIBUTION UNIT. CAP UNUSED DISTRIBUTION UNIT OUTLETS.	1	1/2"			0		0		0	0	0	0
WC-1	WATER CLOSET	GC	GC	KOHLER	K-3519 W/ SEAT K-4666-C	WHITE HIGHLINE 1.0 GPF, 17-1/8"-HIGH, ADA ACCESSIBLE, PRESSURE ASSIST WATER CLOSET WITH OPEN-FRONT SEAT. INSTALL TRIP LEVER ON THE TANK TO THE OPEN SIDE OF THE STALL (ADD -RA TO THE MODEL # FOR RIGHT HAND TRIP LEVER).	2	1/2"		3"	5	0	5	4	10	0	10	8
WH-1	FROST PROOF WALL HYDRANT	GC	GC	WOODFORD	MODEL 65	AUTOMATIC DRAINING, FREEZELESS WALL HYDRANT WITH ANTI-SIPHON VACUUM BREAKER. PROVIDE WITH STEM LONG ENOUGH TO REACH INSIDE THE THERMAL ENVELOPE OF THE BUILDING.	2	3/4"			1	0	1		2	0	2	0
WS-1	WATER SOFTENER	KES	GC	CUNO	CFSM1254E	POINT OF ENTRY HIGH CAPACITY WATER TREATMENT SYSTEM	1	1"			0	0	0	0	0	0	0	0
							48								39.75	20.75	46	70

WATER HEATER SCHEDULE - INSTANTANEOUS

TAG	DESCRIPTION	FURNISHED BY	INSTALLED BY	MANUFACTURER	MODEL	INPUT MBH	DELIVERY	NOTES
DWH-1	DIRECT VENT GAS-FIRED INSTANTANEOUS WATER HEATER	GC	GC	NAVIENT	NPE-240A2	199	354 GPH @ 65" RISE	RATED FLOW RATE: 5.6 GPM @ 67°F RISE THERMAL EFFICIENCY: 96% PROVIDE WITH LEAD FREE "PLUMB EASY VALVE SET". GC SHALL PURCHASE WATER HEATER DIRECTLY THROUGH A NAVIENT AUTHORIZED DISTRIBUTOR (1-800-519-8794 OR WWW.NAVIENT.COM TO LOCATE AUTHORIZED DISTRIBUTOR).
DWH-2	DIRECT VENT GAS-FIRED INSTANTANEOUS WATER HEATER	GC	GC	NAVIENT	NPE-240A2	199	354 GPH @ 65" RISE	RATED FLOW RATE: 5.6 GPM @ 67°F RISE THERMAL EFFICIENCY: 96% PROVIDE WITH LEAD FREE "PLUMB EASY VALVE SET". GC SHALL PURCHASE WATER HEATER DIRECTLY THROUGH A NAVIENT AUTHORIZED DISTRIBUTOR (1-800-519-8794 OR WWW.NAVIENT.COM TO LOCATE AUTHORIZED DISTRIBUTOR).

Consultant:



4635 Trueman Blvd. Suite 250
Hilliard, Ohio 43026
Phone: (614) 751-9610
Fax: (614) 552-5240
Contact: Cliff Kigar
(614) 328-2033
ckigar@nationalengineering.com

FOR CONSTRUCTION

COPYRIGHT 2024
THIS DRAWING IS AN INSTRUMENT OF SERVICE
AND AS SUCH REMAINS THE PROPERTY OF
CHIPOTLE MEXICAN GRILL, INC.. PERMISSION FOR
USE OF THIS DOCUMENT IS LIMITED AND CAN BE
EXTENDED ONLY BY WRITTEN AGREEMENT WITH
CHIPOTLE MEXICAN GRILL, INC..



CHIPOTLE MEXICAN GRILL, INC
PO BOX 182566
COLUMBUS, OH 43218-2566
TELEPHONE: (614) 318-2400
INTERNET: WWW.CHIPOTLE.COM

STORE NO.: 4870
WALNUT HILLS, OH
1202 E. MCMILLAN
CINCINNATI, OH 45206

Issue Record:	
11/03/2023	PERMIT SET
05/08/2024	CONSTRUCTION SET

Revisions: 2 4/25/24 PLAN REVIEW COMMENTS

Drawn:	Checked:
CJK	JEJ




Project No.

2301004

Contents:

PLUMBING SCHEDULES

P600

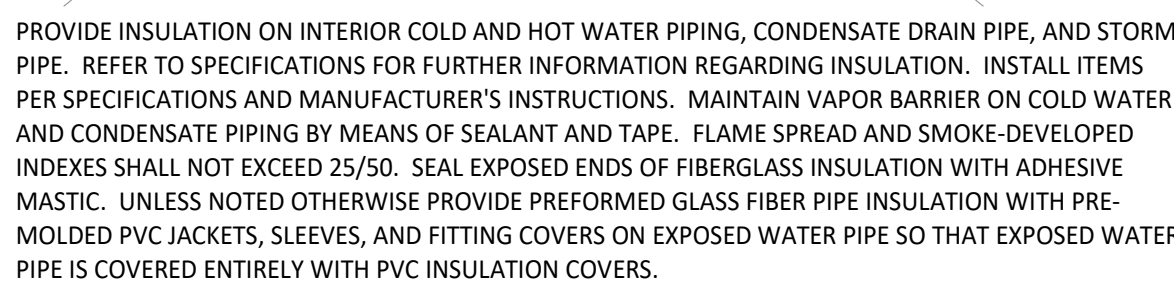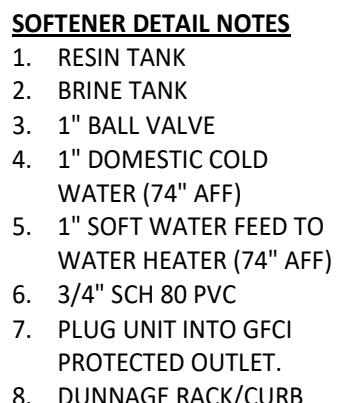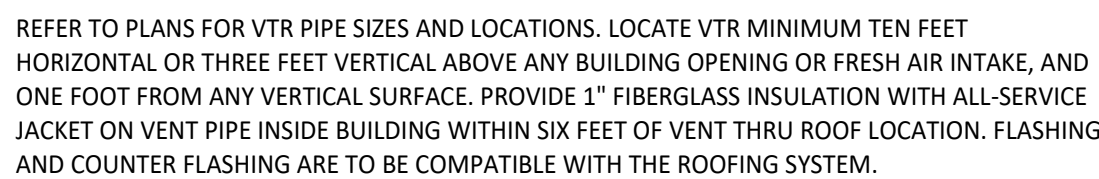

- ### WATER HEATER DETAIL NOTES

1. PROVIDE TWO 90° ELBOWS AND A SCREEN FOR THE FLUE TERMINATION THROUGH THE ROOF PER THE MANUFACTURER'S INSTALLATION INSTRUCTIONS.
2. ROUGH-IN COLD, HOT, AND RECIPE PIPES AT 64" AND GAS PIPE AT 61" BELOW THE FINISHED CEILING.
3. PROVIDE EXPANSION TANK ET-1 AS SHOWN. SUPPORT TANK FROM WALL OR STRUCTURE ABOVE.
4. PROVIDE WATER HEATER RECEPTACLE WITHIN 12" OF THE FINISHED CEILING. FASTEN CORD TIGHT TO THE WALL.
5. PROVIDE PRESSURE RELIEF VALVE. PIPE PRESSURE RELIEF VALVE TO POINT OF DISCHARGE.
6. CONCEAL WATER PIPING WITHIN THE WALL AS SHOWN. INSULATE CONCEALED WATER PIPING. DO NOT PROVIDE INSULATION ON EXPOSED WATER PIPING AT WATER HEATER.
7. INSTALL "PLUMB EASY VALVE SET" EXPOSED AT THE COLD AND HOT WATER CONNECTIONS TO THE WATER HEATER AS SHOWN.
8. IF THE PIPE SIZES AS SHOWN ON THE PLUMBING PLANS IS LARGER THAN THE WATER HEATER CONNECTIONS SIZES, PROVIDE REDUCERS WITHIN 6" OF THE WATER HEATER.
9. PIPE PRESSURE RELIEF VALVE DISCHARGE AND FLUE CONDENSATE DRAIN TO THE POINT OF DISCHARGE. DRAIN THROUGH AN AIR GAP.
10. PROVIDE AN EXPOSED DRIP LEG AND LINE-SIZE GAS VALVE ON THE GAS SERVICE TO THE WATER HEATER.
11. CONCEAL GAS PIPING IN THE WALL AS SHOWN.
12. PROVIDE 1/2" PVC PIPE FROM THE FLUE CONDENSATE CONNECTION TO THE FLOOR DRAIN OR MOP BASIN. DRAIN THROUGH AN AIR GAP.
13. INSTALL THE TANKLESS WATER HEATER WITH THE TOP OF THE WATER HEATER BETWEEN 9" & 12" OF THE FINISHED CEILING.
14. PROVIDE A 2"Ø PVC PIPE FROM THE TANKLESS WATER HEATER TO THE POINT OF DISCHARGE. SLOPE HORIZONTAL SECTION OF THE FLUE 1/4" PER FOOT TOWARDS THE WATER HEATER.
15. PROVIDE A SCREENED AIR INTAKE WITH TWO 90° ELBOWS ABOVE THE ROOF PER THE MANUFACTURER'S INSTALLATION INSTRUCTIONS.
16. CONCEAL DRAIN LINES IN WALL PER DETAIL 9/THIS SHEET.
17. PROVIDE COMMUNICATION CABLE CONCEALED IN WALL BETWEEN WATER HEATERS.
18. IF WATER HEATERS ARE INSTALLED WITH A COMMON VENT SYSTEM THEN PROVIDE THE NAVEN COMMON VENT COLLAR KIT WITH BACK-DRAFT DAMPER PER THE MANUFACTURER'S INSTALLATION MANUAL.

- WATER HEATER GENERAL NOTES**

- A. CLEAN INLET STRAINERS AFTER CONSTRUCTION HAS COMPLETED AND PRIOR TO TURNOVER OF THE BUILDING TO THE TENANT.
- B. INSTALL PIPING WITH AS FEW ELBOWS AS POSSIBLE.
- C. MAINTAIN REQUIRED CLEARANCE TO COMBUSTIBLE MATERIALS.
- D. ADJUST WATER HEATER TO A SETPOINT OF 120° F.

Consultant:



4635 Trueman Blvd. Suite 250
Hilliard, Ohio 43026
Phone: (614) 751-9610
Fax: (614) 552-5240
Contact: Cliff Kigar
(614) 328-2033
ckigar@nationalengineering.com

FOR CONSTRUCTION

COPYRIGHT 2024
THIS DRAWING IS AN INSTRUMENT OF SERVICE
AND AS SUCH REMAINS THE PROPERTY OF
CHIPOTLE MEXICAN GRILL, INC.. PERMISSION FOR
USE OF THIS DOCUMENT IS LIMITED AND CAN BE
EXTENDED ONLY BY WRITTEN AGREEMENT WITH
CHIPOTLE MEXICAN GRILL, INC..



CHIPOTLE MEXICAN GRILL, INC.
PO BOX 182566
COLUMBUS, OH 43218-2566
TELEPHONE: (614) 318-2400
INTERNET: WWW.CHIPOTLE.COM

STORE NO.: 4870

WALNUT HILLS, OH
1202 E. MCMILLAN
CINCINNATI, OH 45206

Issue Record:	
<u>11/03/2023</u>	<u>PERMIT SET</u>
05/08/2024	CONSTRUCTION SET

2 4/25/24 PLAN REVIEW COMMENTS

Drawn:	Checked:
CJK	JEJ

Project No.
2301004

Contents:

PLUMBING DETAILS

P700

SECTION 16011 TEMPORARY & PERMANENT ELECTRICAL SERVICE

- PART 1 - GENERAL
- 1.1 DEFINITIONS
- A. GFCI: Ground fault current interrupter.
- B. RMS: Root Mean Square
- C. SPD: Single Pole, Double Throw
- 1.2 USE CHARGES
- A. General: Cost or use charges for temporary facilities are not chargeable to Tenant, Architect, or Engineer and shall be included in the Contract Sum. Allow other entities to use temporary services and facilities without cost, including, but not limited to, the following:
- Tenant's construction forces.
 - Occupants of Project.
 - Architect.
 - Engineer.
 - Testing agencies.
 - Personnel of authorities having jurisdiction.
- B. Permanent Service: Coordinate with building Tenant and utility company to establish permanent service upon completion of the project. Contractor shall pay for all permits, aid-to-construction charges, and related fees associated with the new service.
- 1.3 NOTIFICATION
- A. Coordinate with Tenant to provide 72 hour written notification to other tenants of any power interruptions. Notification shall state the estimated time and duration of the electrical outage.
- 1.4 QUALITY ASSURANCE
- A. Standards: Comply with ANSI A10.6, NECA's "Temporary Electrical Facilities," and NFPA 241.
- Trade Jurisdictions: Assigned responsibilities for installation and operation of temporary utilities are not intended to interfere with trade regulations and union jurisdictions.
 - Electric Service: Comply with NECA, NEMA and UL standards and regulations for temporary electric service. Install service to comply with NFPA 70.
 - Comply with OSHA standards and regulations.

- PART 2 - PRODUCTS
- 2.1 MATERIALS
- A. Electrical Outlets: Properly configured, NEMA-polarized outlets to prevent insertion of 110- to 120-V plugs into higher-voltage outlets; equipped with ground-fault circuit interrupters, reset button, and pilot light.
- B. Power Distribution System Circuits: Where permitted and overhead and exposed for surveillance, wiring circuits, not exceeding 125-V ac, 20-A rating, and lighting circuits may be nonmetallic sheathed cable.
- C. Main panelboard with disconnect.
- D. Temporary lighting.
- E. 120 volt receptacles with overcurrent protection.
- F. Enclosures: NEMA AB 1 and NEMA KS 1 to meet environmental conditons of installed location.
- Outdoor Locations: NEMA 250, Type 3R.
- PART 3 - EXECUTION
- 3.1 INSTALLATION
- A. Electric Power Service: Provide weatherproof, grounded electric power service and distribution system of sufficient size, capacity, and power characteristics during construction period. Include meters, transformers, and overload-protected disconnecting means.
- Install power distribution wiring overhead and rise vertically where least exposed to damage.
- B. Electric Distribution: Provide receptacle outlets adequate for connection of power tools and equipment.
- Provide waterproof connectors to connect separate lengths of electrical power cords if single lengths will not reach areas where construction activities are in progress. Do not exceed safe length-voltage ratio.
 - Provide metal conduit, tubing, or metallic cable for wiring exposed to possible damage. Provide rigid steel conduits for wiring exposed on grades, floors, decks, or other traffic areas.
 - Provide metal conduit enclosures or boxes for wiring devices.
 - Provide 4-gang outlets, spaced so 1 DO-foot (30-m) extension cord can reach each area for power hand tools and task lighting. Provide a separate 125-V ac, 20-A circuit for each outlet.
- C. Lighting: Provide temporary lighting with local switching that provides adequate illumination for construction operations and traffic conditions.
- Install and operate temporary lighting that fulfills security and protection requirements without operating entire system.
 - Provide one 100-W incandescent lamp (or equivalent) every 50 feet (15 m) in traffic areas.
 - Install exterior-yard site lighting that will provide adequate illumination for construction operations, parking and traffic conditions, and signage visibility when the Work is being performed.

END OF SECTION 16011

SECTION 16060 - GROUNDING AND BONDING

- PART 1 - GENERAL
- 1.1 SUMMARY
- A. This Section includes grounding of electrical systems and equipment. Grounding requirements specified in this Section may be supplemented by special requirements of systems described in other Sections.
- 1.2 QUALITY ASSURANCE
- A. Testing Agency Qualifications: Testing agency as defined by OSHA in 29 CFR 1910.7 or a member company of the International Electrical Testing Association and that is acceptable to authorities having jurisdiction.
- Testing Agency's Field Supervisor: Person currently certified by the International Electrical Testing Association to supervise on-site testing specified in Part 3.
- B. Electrical Components, Devices, and Accessories: Listed and labeled as defined in NFPA 70, Article 100, by a testing agency acceptable to authorities having jurisdiction, and marked for intended use.
- Comply with UL 467.
- PART 2 - PRODUCTS
- 2.1 GROUNDING CONDUCTORS
- A. For insulated conductors, comply with Division 16 Section "Wiring Methods."
- B. Material: Copper.
- C. Equipment Grounding Conductors: Insulated with green-colored insulation.
- D. Grounding Electrode Conductors: Stranded cable.
- E. Bare Copper Conductors: Comply with the following:
- Solid Conductors: ASTM B 3.
 - Assembly of Stranded Conductors: ASTM B 8.
- 2.2 CONNECTOR PRODUCTS
- A. Comply with IEEE 837 and UL 467; listed for use for specific types, sizes, and combinations of conductors and connected items.
- PART 3 - EXECUTION
- 3.1 APPLICATION
- A. Use only copper conductors.
- B. In raceways, use insulated equipment grounding conductors.
- C. Equipment Grounding Conductor Terminations: Use bolted pressure clamps.
- D. Grounding Bus: Install in electrical and telephone equipment rooms, in rooms housing service equipment, and elsewhere as indicated.
- Use insulated spacer; space 1 inch from wall and support from wall 6 inches above finished floor, unless otherwise indicated.
 - At doors, route the bus up to the top of the door frame, across the top of the doorway, and down to the specified height above the floor.
- 3.2 EQUIPMENT GROUNDING CONDUCTORS
- A. Comply with NFPA 70, Article 250, for types, sizes, and quantities of equipment grounding conductors, unless specific types, larger sizes, or more conductors than required by NFPA 70 are indicated.
- 3.3 INSTALLATION
- A. Grounding Conductors: Route along shortest and straightest paths possible, unless otherwise indicated. Avoid obstructing access or placing conductors where they may be subjected to strain, impact, or damage.
- 3.4 CONNECTIONS
- A. General: Make connections so galvanic action or electrolysis possibility is minimized. Select connectors, connection hardware, conductors, and connection methods so metals in direct contact will be galvanically compatible.
- B. Equipment Grounding Conductor Terminations: For No. 8 AWG and larger, use pressure-type grounding lugs. No. 10 AWG and smaller grounding conductors may be terminated with winged pressure-type connectors.
- C. Tighten screws and bolts for grounding and bonding connectors and terminals according to manufacturer's published torque-tightening values. If manufacturer's torque values are not indicated, use those specified in UL 486A.
- D. Compression-Type Connections: Use hydraulic compression tools to provide correct circumferential pressure for compression connectors. Use tools and dies recommended by connector manufacturer. Provide embossing die code or other standard method to make a visible indication that a connector has been adequately compressed on grounding conductor.

END OF SECTION 16060

SECTION 16100 - WIRING METHODS

- PART 1 - GENERAL
- 1.1 SECTION REQUIREMENTS
- A. Summary: Building wire and cable and associated splices, connectors, and terminations for wiring systems rated 600 V and less, and twisted-pair cable; and raceways and boxes.
- PART 2 - PRODUCTS
- 2.1 WIRES AND CABLES
- A. Connectors and Splices: Wiring connectors of size, ampacity rating, material, and type and class for application and for service indicated.
- 2.2 RACEWAYS
- A. Wireways: Screwed cover type, with manufacturers standard finish.
- B. Outlet and Raceway Boxes: Sheet metal boxes, except use cast-metal boxes at exterior, interior exposed, and interior damp locations.
- C. Pull and Junction Boxes: Sheet metal boxes, except use nonmetallic boxes with gasketed covers at exterior and interior damp locations.
- 2.3 ENCLOSURES
- A. Hinged-Cover Enclosures: NEMA 250, steel enclosure with continuous hinge cover and flush latch. Finish inside and out with manufacturer's standard enamel.
- B. Cabinets: NEMA 250, Type 1, unless otherwise indicated.
- PART 3 - EXECUTION
- 3.1 INSTALLATION
- A. Install wires and cables according to the NECA's "Standard of Installation."
- B. Wiring at Outlets: Install with at least 12 inches of slack conductor at each outlet.
- C. Conceal wiring, unless otherwise indicated, within finished walls, ceilings, and floors.
- D. Boxes and Enclosures: In damp or wet locations use NEMA 250, Type 4, stainless steel.
- E. Use raceway fittings compatible with raceway and suitable for use and location. For intermediate metal conduit, use threaded rigid steel conduit fittings, unless otherwise indicated.
- F. Raceways Embedded in Slabs: Install in middle third of the slab thickness where practical, and leave at least 1 -inch concrete cover.
- G. Install exposed raceways parallel to or at right angles to nearby surfaces or structural members, and follow the surface contours as much as practical.
- H. Join raceways with fittings designed and approved for the purpose and make joints tight. Use bonding bushings or wedges at connections subject to vibration. Use bonding jumpers where joints cannot be made tight. Use insulating bushings to protect conductors.
- I. Install pull wires in empty raceways. Use No. 14 AWG zinc-coated steel or monofilament plastic line having not less than 200-lb tensile strength. Leave not less than 18 inches of slack at each end of the pull wire.
- J. Install raceway sealing fittings where required by the NEC and at wiring entrances to refrigerated spaces. Locate at suitable, approved, accessible locations and fill them with UL-listed sealing compound. For concealed raceways, install each fitting in a flush steel box with a blank cover plate having a finish similar to that of adjacent plates or surfaces.
- K. Stub-up Connections for Equipment: Extend conductors to equipment with rigid metal conduit; flexible metal conduit may be used 3 inches above the floor.
- L. Install a separate green ground conductor in surface metal raceway from the junction box supplying the raceway to receptacle and fixture ground terminals.
- 3.2 IDENTIFICATION MATERIALS AND DEVICES
- A. Install at locations for most convenient viewing without interference with operation and maintenance of equipment.
- B. Coordinate names, abbreviations, colors, and other designations used for electrical identification with corresponding designations indicated in the Contract Documents or required by codes and standards. Use consistent designations throughout Project.
- C. Identify raceways and cables with color banding as follows:
- Bands: Pre-tensioned, snap-around, colored plastic sleeves or colored encircling conduit, and place adjacent bands of two-color markings in contact, side by side.
 - Band Locations: At changes in direction, at penetrations of walls and floors, at 50-foot maximum intervals in straight runs, and at 25-foot maximum intervals in congested areas.
 - Colors: As follows:
 - Telecommunication System: Green and yellow.
- D. Color-code System secondary service, feeder, and branch-circuit conductors throughout the secondary electrical system as follows:
- | | | |
|-------------|----------|----------|
| | 120/208V | 277/480V |
| 1. Phase A: | Black | Brown |
| 2. Phase B: | Red | Orange |
| 3. Phase C: | Blue | Yellow |
| 4. Neutral: | White | Gray |
| 5. Ground: | Green | Green |

END OF SECTION 16100

SECTION 16140 - WIRING DEVICES

- PART 1 - GENERAL
- 1.1 SECTION REQUIREMENTS
- A. Submittals: None.
- B. Comply with NEMA WD 1.
- C. Comply with NFPA 70.
- PART 2 - PRODUCTS
- 2.1 DEVICES
- A. General: Listed and labeled as defined in NFPA 70, Article 100, by a testing agency acceptable to authorities having jurisdiction.
- B. Color: Per Material Schedule on sheet E010.
- C. Receptacles: Heavy- Duty grade, NEMA WD6, Configuration 5-20R unless otherwise indicated.
- D. Ground-Fault Circuit Interrupter Receptacles: integral duplex receptacle; for installation in box without an adapter. Feed-through type, with a 2-3/4-inch- deep outlet
- E. Isolated-Ground Receptacles: Equipment grounding contacts connected only to the green grounding screw terminal of the device with inherent electrical isolation from mounting strap.
- F. Snap Switches: Heavy-duty, quiet type.
- G. Wall Plate: Per Material Schedule on sheet E010.
- H. Floor Service Fittings: Modular, above-floor, dual-service units suitable for wiring method used.
- PART 3 - EXECUTION
- 3.1 INSTALLATION
- A. Install devices and assemblies plumb and secure.
- B. Mount devices flush with long dimension vertical unless otherwise indicated.
- C. Protect devices and assemblies during painting.
- D. Install wall plates when painting is complete and paint is cured.

END OF SECTION 16140

SECTION 16442 - PANELBOARDS

- PART 1 - GENERAL
- 1.1 SECTION REQUIREMENTS
- A. Submittals: None.
- B. Comply with NFPA 70.
- C. Comply with NEMA PB 1.
- PART 2 - PRODUCTS
- 2.1 PANELBOARDS AND LOAD CENTERS
- A. Manufacturers: Subject to compliance with requirement, provide products by one of the following:
- Panelboards, Overcurrent Protective Devices, Controllers, Contactors, and Accessories:
 - Square D Co.
 - Eaton Corp.; Cutler-Hammer Products.
 - General Electric Co.; Electrical Distribution & Control Div.
 - Siemens Energy & Automation.
 - Recessed, NEMA PB 1, Type 1.
 - Load Center Capacity: as shown on drawings.
 - Front: Secured to box with concealed trim clamps.
 - Doors: With concealed hinges, flush catches, and tumbler locks, all keyed alike.
 - Bus: Hard drawn copper of 98 percent conductivity.
 - Molded-Case Circuit Breakers: NEMA AB 1, plug-in type, Single-handle for multiple circuit breakers. Appropriate for application, including Type SWD for repetitive switching lighting loads and Type HACR for heating, air-conditioning, and refrigerating equipment.
 - Contactors: NEMA ICS 2, Class A combination contactors.
- PART 3 - EXECUTION
- 3.1 INSTALLATION
- A. Install panelboards and accessory items according to NEMA PB 1.1. Provide typed, permanently-mounted English and Spanish circuit directories showing the panel schedules as installed in each panelboard.
- B. Mounting Heights: Top of trim 74 inches above finished floor, unless otherwise indicated.
- C. Future Circuit Provisions at Flush Panel boards: Stub four empty 3/4-inch conduits from panelboard into accessible or designated ceiling space.
- D. Wiring in Panelboard Gutters: Arrange conductors into groups, bundle and wrap with wire ties according to NEC guidelines.
- E. Tighten electrical connectors and terminals, including grounding connections, according to manufacturer's published torque-tightening values. Where manufacturer's torque values are not indicated, use those specified in UL 486A.
- F. Perform visual and mechanical inspections and electrical tests stated in NETA ATS.

END OF SECTION 16442

SECTION 16500 - LIGHTING

- PART 1 - GENERAL
- 1.1 SECTION REQUIREMENTS
- A. Submittals: None.
- B. Fixtures, Emergency Lighting Units, and Accessories: Listed and labeled as defined in NFPA 70, Article 100, by a testing agency acceptable to authorities having jurisdiction.
- C. Coordinate ceiling-mounted luminaires with ceiling construction, mechanical work, and security and fire-prevention features mounted in ceiling space and on ceiling.
- PART 2 - PRODUCTS
- 2.1 FIXTURES AND FIXTURE COMPONENTS, GENERAL
- A. Metal Parts: Free from burrs, sharp corners, and edges. Steel, unless otherwise indicated. Form and support to prevent warping and sagging.
- B. Doors, Frames, and Other Internal Access: Smooth operating, free from light leakage under operating conditions, and arranged to permit re-lamping without use of tools. Arrange doors, frames, lenses, diffusers, and other pieces to prevent accidental falling during re-lamping and when secured in operating position.
- C. Lenses, Diffusers, Covers, and Globes: 100 percent virgin acrylic plastic or annealed crystal glass, unless otherwise indicated.
- PART 3 - EXECUTION
- 3.1 INSTALLATION
- A. Set units level, plumb, and square with ceiling and walls, and secure.
- B. Support for Recessed and Semirecessed Grid-Type Fluorescent Fixtures: Install ceiling support system rods or wires at a minimum of 4 rods or wires for each fixture, located not more than 6 inches from fixture corners.
- C. Support for Suspended Fixtures: Support according to manufacturers' recommendations.
- D. Lamping: Where specific lamp designations are not indicated, lamp units according to manufacturer's written instructions.

END OF SECTION 16500

ELECTRICAL SYMBOLS

- CONDUIT CONCEALED ABOVE THE CEILING, IN A WALL, OR IN A RACEWAY
- CONDUIT CONCEALED BELOW THE SLAB
- HOME-RUN TO PANELBOARD AND CIRCUIT NUMBER SHOWN
- PLAN NOTE: SEE PLAN NOTES LISTED ON THE SAME SHEET FOR NOTE MEANING
- DISCONNECT SWITCH:
- X = SWITCH RATING
- Y = FUSE SIZE (NF = NON-FUSED)
- Z = NUMBER OF POLES
- JUNCTION BOX
- ELECTRIC PANELBOARD
- GENERAL PURPOSE 1-POLE SWITCH
- MANUAL STARTER WITH PILOT LIGHT
- NEMA 5-20R 1-PLEX RECEPTACLE
- NEMA 5-20R DUPLEX RECEPTACLE
- NEMA 5-20R DOUBLE-DUPLEX RECEPTACLES
- NEMA 5-20R DUPLEX COMBINATION ISOLATED GROUND/GFI RECEPTACLE PASS & SEYMOUR MODEL#2095IGTRGRY (GRAY)
- OTHER RECEPTACLE - SEE PLAN FOR RATING AND TYPE
- JUNCTION BOX FOR RJ-45 DATA OUTLETS. PROVIDE 1" CONDUIT WITH PULL STRING FROM J-BOX TO ABOVE OFFICE CEILING. TERMINATE CONDUIT WITH CONDUIT BUSHING.
- DOUBLE GANG JUNCTION BOX FOR RJ-45 DATA OUTLETS. PROVIDE 1" CONDUIT WITH PULL STRING FROM J-BOX TO ABOVE OFFICE CEILING. TERMINATE CONDUIT WITH CONDUIT BUSHING.
- JUNCTION BOX FOR RJ-11 TELEPHONE OUTLETS. PROVIDE 1" CONDUIT WITH PULL STRING FROM J-BOX TO ABOVE OFFICE CEILING. TERMINATE CONDUIT WITH CONDUIT BUSHING.
- SECURITY SYSTEM KEYPAD: PROVIDE A RECESSED JB WITH A 1/2" CONDUIT TO ABOVE THE DROP TILE CEILING IN THE OFFICE AREA AND TERMINATE WITH A CONDUIT BUSHING

ELECTRICAL MATERIAL SCHEDULE

CATEGORY	APPLICATION	ALLOWABLE MATERIAL
CONDUCTORS	#10 AWG AND SMALLER	SOLID CU, TYPE THHN/THWN OR XHHW
	#8 AWG AND LARGER	STRANDED CU, TYPE THHN/THWN OR XHHW
CONDUITS	INDOOR, EXPOSED	ELECTRICAL METALLIC TUBING U.N.O.
	INDOOR, WITHIN 1-1/2" OF ROOF DECK	INTERMEDIATE METAL CONDUIT
	INDOOR, CONCEALED ABOVE GRADE	ELECTRICAL METALLIC TUBING, FLEXIBLE METAL CONDUIT, OR METAL CLAD CABLE
	CONNECTION TO VIBRATING EQUIPMENT (EXPOSED WET OR DAMP LOCATIONS)	LIQUIDTIGHT FLEXIBLE METAL CONDUIT
	CONNECTION TO VIBRATING EQUIPMENT (EXPOSED INDOOR DRY LOCATIONS)	FLEXIBLE METAL CONDUIT
	OUTDOOR, ABOVE GRADE, EXPOSED OR CONCEALED	INTERMEDIATE METAL CONDUIT
WIRING DEVICES	LOW VOLTAGE, INDOOR, ABOVE GRADE	ELECTRICAL METALLIC TUBING
	LOW OR LINE VOLTAGE, BELOW GRADE	RIGID NONMETALLIC CONDUIT (SCHEDULE 40 PVC)
	IN KITCHEN, OFFICE, OR NON-PUBLIC SPACES	GRAY DEVICE WITH STAINLESS STEEL COVER PLATE
	IG OR IG/GFI RECEPTACLES	GRAY DEVICE WITH STAINLESS STEEL COVER PLATE
	ON DRYWALL IN DINING ROOM	WHITE DEVICE WITH WHITE COVER PLATE
	ON HOT ROLLED STEEL, RICHLITE, OR OTHER BLACK FINISHES	BLACK DEVICE WITH BLACK COVER PLATE
	IN RESTROOMS	WHITE DEVICE WITH WHITE COVER PLATE

ELECTRICAL GENERAL NOTES

- A. GENERAL NOTES APPLY TO ELECTRICAL SHEETS.
- B. ELECTRICAL WORK SHALL BE DONE IN ACCORDANCE WITH THE ELECTRICAL CODE AND IN ACCORDANCE WITH THE AUTHORITY HAVING JURISDICTION. SEE ARCHITECTURAL SHEETS FOR THE PREVAILING CODES.
- C. WIRING SHALL BE (2)#12, #12 G IN 3/4" C UNLESS NOTED OTHERWISE.
- D. INDIVIDUAL CONDUIT HOME RUNS SHOWN SHALL NOT BE CONSOLIDATED.
- E. CIRCUIT EMERGENCY LIGHTS, ILLUMINATED EXIT SIGNS, AND NIGHT LIGHTS AHEAD OF LOCAL SWITCHING.
- F. INSTALL WALL SWITCHES AT 48" AFF TO CENTER OF SWITCH AND RECEPTACLES AT 18" AFF TO CENTER OF RECEPTACLE UNLESS NOTED OTHERWISE.
- G. INSTALL CONDUIT CONCEALED ABOVE THE CEILING, IN WALLS, OR IN RACEWAYS.
- H. PROVIDE 1" CONDUIT WITH PULL STRING FROM EACH J-BOX FOR TELEPHONE OR DATA JACKS TO ABOVE OFFICE CEILING. SEE MATERIAL SCHEDULE FOR ALLOWABLE CONDUIT MATERIALS. PROVIDE CONDUITS WITH MINIMAL ELBOWS AND TERMINATE CONDUITS ABOVE OFFICE CEILING WITH CONDUIT BUSHING.
- I. THE TERM "FURNISH" MEANS SUPPLY AND DELIVER TO THE PROJECT SITE, READY FOR UNLOADING, UNPACKING, ASSEMBLY, INSTALLATION, AND SIMILAR OPERATIONS. THE TERM "INSTALL" DESCRIBES THE OPERATIONS AT THE PROJECT SITE INCLUDING THE ACTUAL UNLOADING, UNPACKING, ASSEMBLY, ERECTING, PLACING, ANCHORING, APPLYING, WORKING TO DIMENSION, FINISHING, CURING, PROTECTING, CLEANING, AND SIMILAR OPERATIONS. THE TERM "PROVIDE" MEANS TO FURNISH AND INSTALL, COMPLETE AND READY FOR THE INTENDED USE.
- J. DIMENSIONS SHOWN IN ELECTRICAL ELEVATIONS ARE FROM THE WALL FRAMING UNLESS NOTED OTHERWISE.
- K. PROVIDE LABELING CALLED FOR IN THE ELECTRICAL DRAWINGS USING ENGRAVED PHENOLIC PLATES (WHITE WITH BLACK LETTERING).

ELECTRICAL ABBREVIATIONS

AFF	ABOVE FINISHED FLOOR
AFG	ABOVE FINISHED GRADE
C	CONDUIT
(E)	EXISTING
EXT'G	EXISTING
G	GROUND
GFCI	GROUND FAULT CIRCUIT INTERRUPT
IG	ISOLATED GROUND
JB	JUNCTION BOX
NL	NORMAL POWER EGRESS LIGHT
S	SURFACE MOUNTED
WP	WEATHERPROOF
CO2AS	TENANT'S CO2 ALARM SUPPLIER
GC	GENERAL CONTRACTOR
HES	TENANT'S HVAC EQUIPMENT SUPPLIER
KES	TENANT'S HOOD SUPPLIER
HS	TENANT'S KITCHEN EQUIPMENT SUPPLIER
TAB	TENANT'S TEST AND BALANCE VENDOR
TCC	TENANT'S CABLING CONTRACTOR
TDC	TENANT'S DUCT CLEANER
TEMS	TENANT'S ENERGY MANAGEMENT SYSTEM SUPPLIER
TLS	TENANT'S LIGHT/LAMP SUPPLIER
TMB	TENANT'S MENU BOARD SUPPLIER
TMS	TENANT'S MILLWORK SUPPLIER
TP	TENANT'S PHONE SUPPLIER
TPS	TENANT'S PANELBOARD SUPPLIER
TRG	TENANT'S RAILING SUPPLIER
TSV	TENANT'S SIGN VENDOR
TUV	TENANT'S UV SANITIZER SUPPLIER
WCS	TENANT'S WALK-IN COOLER SUPPLIER
WHS	TENANT'S WATER HEATER SUPPLIER

Consultant:



4635 Trueman Blvd. Suite 250
Hilliard, Ohio 43026
Phone: (614) 751-9610
Fax: (614) 552-5240
Contact: Cliff Kigar
(614) 328-2033
ckigar@nationalengineering.com

FOR CONSTRUCTION

COPYRIGHT 2024
THIS DRAWING IS AN INSTRUMENT OF SERVICE
AND AS SUCH REMAINS THE PROPERTY OF
CHIPOTLE MEXICAN GRILL, INC.. PERMISSION FOR
USE OF THIS DOCUMENT IS LIMITED AND CAN BE
EXTENDED ONLY BY WRITTEN AGREEMENT WITH
CHIPOTLE MEXICAN GRILL, INC..



CHIPOTLE MEXICAN GRILL, INC.
PO BOX 182566
COLUMBUS, OH 43218-2566
TELEPHONE: (614) 338-2400
INTERNET: WWW.CHIPOTLE.COM

STORE NO.: 4870

WALNUT HILLS, OH
1202 E. MCMILLAN
CINCINNATI, OH 45206

Issue Record:	
11/03/2023	PERMIT SET
05/08/2024	CONSTRUCTION SET

Revisions:	
2 4/25/24	PLAN REVIEW COMMENTS

Drawn:	Checked:
CJK	JEJ

Project No.

2301004

Contents:

ELECTRICAL SPECIFICATIONS

E010

LIGHTING FIXTURE SCHEDULE

TAG	QUANTITY	TYPE	MOUNT	FURNISHED BY	INSTALLED BY	MANUFACTURER	MODEL	LAMP(S)	VOLTS	WATTS	SPECIAL REQUIREMENTS
A1	11	2x2 LED LENSED TROFFER	LAY-IN	TLS	GC	NORA LIGHTING	NPDBL-E22/334 W	(1) 3000K LED	120	30	COMPATIBLE WITH 0-10V DIMMING, FACTORY LOCKED TO 3000K
B1	8	RECESSED 6IN CAN LIGHT	CEILING	TLS	GC	NORA LIGHTING	NHIC-6G24ATFL with NTM-57W/M1 Trim	(1) 17W ECOSTORY ECO-PAR38C-17-GU24-27K-25D LED (25"-2700K) W/ GU 24 BASE	120	17	
B2	24	RECESSED 6IN CAN LIGHT W/ LED TRIM	CEILING	TLS	GC	NORA LIGHTING	NHIC-6G24ATFL WITH NLCBC-65130WW LED TRIM	INTEGRAL 3000K LED	120	17	LED TRIM FURNISHED WITH GU24 SOCKET ADAPTER
B3	2	RECESSED 6IN CAN LIGHT W/ BLACK LED TRIM	CEILING	TLS	GC	NORA LIGHTING	NHIC-6G24ATFL WITH NLCBC2-65127B8 LED TRIM	INTEGRAL 3000K LED	120	12	BLACK LED TRIM FURNISHED WITH GU24 SOCKET ADAPTER
C0	4	LOW PROFILE LED - 1 FT	SURFACE	TLS	GC	HERA LIGHTING	EL/LED/12/WW	INTEGRAL 3000K LED	120	5	FURNISHED WITH COVERS, CONNECTORS, AND ONE HARDWIRE BOX OR CORD/PLUG PER SECTION
C1	1	LOW PROFILE LED - 2 FT	SURFACE	TLS	GC	HERA LIGHTING	EL/LED/22/WW	INTEGRAL 3000K LED	120	9	FURNISHED WITH COVERS, CONNECTORS, AND ONE HARDWIRE BOX OR CORD/PLUG PER SECTION
C2	20	LOW PROFILE LED - 3 FT	SURFACE	TLS	GC	HERA LIGHTING	EL/LED/34/WW	INTEGRAL 3000K LED	120	12	FURNISHED WITH COVERS, CONNECTORS, AND ONE HARDWIRE BOX OR CORD/PLUG PER SECTION
C3	4	LOW PROFILE LED - 4 FT	SURFACE	TLS	GC	HERA LIGHTING	EL/LED/46/WW	INTEGRAL 3000K LED	120	15	FURNISHED WITH COVERS, CONNECTORS, AND ONE HARDWIRE BOX OR CORD/PLUG PER SECTION
C4	1	LOW PROFILE LED - 5 FT	SURFACE	TLS	GC	HERA LIGHTING	EL/LED/59/WW	INTEGRAL 3000K LED	120	18	FURNISHED WITH COVERS, CONNECTORS, AND ONE HARDWIRE BOX OR CORD/PLUG PER SECTION
E1	6	EMERGENCY LIGHT - DUAL HEAD	VARIOUS	TLS	GC	EXITRONIX	LED-90	(2) SPECIAL LED	120	2	90 MINUTE BATTERY BACKUP
E2	4	EXTERIOR REMOTE EMERGENCY LIGHT	VARIOUS	EXT'G	EXT'G	EXITRONIX	MLED1-B-WP	(1) SPECIAL LED	4	1	LOW VOLTAGE REMOTE EMERGENCY LIGHT POWERED BY REMOTE-CAPABLE EXIT SIGN WITH MOUNTING PLATE
E4	4	WHITE EXIT SIGN WITH EMERGENCY LIGHT - STANDARD RED LETTERS	VARIOUS	EXT'G	EXT'G	EXITRONIX	CLED-U-WH	(1) SPECIAL LED	120	2	90 MINUTE BATTERY BACKUP WITH INTEGRAL EMERGENCY LIGHT, REMOTE HEAD CAPABLE
E7	7	EMERGENCY LIGHT	VARIOUS	TLS	GC	DUAL-LITE	EV2	(2) 1W INTEGRAL LED	120	1	90 MINUTE BATTERY BACKUP
H1	8	HOOD LIGHT	SURFACE	THS/TLS	THS	VAPOR PROOF LIGHT FIXTURE FURNISHED WITH HOOD	FURNISHED WITH HOOD	(1) TCP L16A19N1527K	120	23	INSTALL LAMP FURNISHED SEPARATELY BY LIGHTING SUPPLIER
J4	2	DECORATIVE PENDANT	SURFACE	TLS	GC	BARNLIGHT	BLE-C-CPT10-ASH-100-SBK-100-CAW	GREEN CREATIVE 9A19DIM/927/GU24/R	120	9	WITH BLACK LAMP SHADE, BLACK CORD, AND OAK LAMP HOLDER
P6	1	DECORATIVE DINING ROOM PENDANT	SURFACE	TLS	GC	BARN LIGHT	BLE-C-JGT-133-35630-3	INTEGRAL LED	120	30	HARDWIRED SET OF (3) HEADS WITH UNIVERSAL CANOPY AND STANDARD BLACK CABLES
S1	1	DRIVE-UP PICK-UP WINDOW CHIME/STROBE	WALL	TLS	GC	FEDERAL SIGNAL	SLM500B W/ SLMBW-012-024	INTEGRAL	16	0	SET SWITCH A TO "CHIME 1 SINGLE" (11011) AND SWITCH B TO "CHIME 2 SINGLE" (00111)
T1	9	TRACK HEAD	TRACK	TLS	GC	JUNO	R605L 30K 90CRI PDIM WFL BL	INTEGRAL LED	120	10	BLACK CYLINDER TRACK HEAD W/ UNIVERSAL 120V TRAC ADAPTER AND WIDE FLOOD BEAM
T-6	3	TRACK (6 FEET)	SURFACE	TLS	GC	JUNO	T 6FT BK	N/A	120	0	SINGLE CIRCUIT, BLACK FINISH
TCL-0.5	1	CURRENT LIMITER (60W)	SURFACE	TLS	GC	JUNO	TCLFM11 BL W/ TCLCB 0.5A BLCK	N/A	120	0	BLACK CURRENT LIMITING END FEED
TCL-1	1	CURRENT LIMITER (120W)	SURFACE	TLS	GC	JUNO	TCLFM11 BL W/ TCLCB 1A BLCK	N/A	120	0	BLACK CURRENT LIMITING END FEED
W1	4	WIC LED FIXTURE	SURFACE	WCS	GC	FURNISHED WITH WIC	FURNISHED WITH WIC	INTEGRAL LED	120	29	WET-RATED COOLER FIXTURE
X1	1	RECESSED 6IN CAN LIGHT W/ LED TRIM	CEILING	EXT'G	EXT'G	NORA LIGHTING	NHIC-6G24ATFL WITH NLCBC-65130WW LED TRIM	INTEGRAL 3000K LED	120	17	LED TRIM FURNISHED WITH GU24 SOCKET ADAPTER
X6	3	EXTERIOR FLOOD LIGHT	SURFACE	EXT'G	EXT'G	RAB LIGHTING	LFLED5YB	INTEGRAL LED	120	10	(2) LFLED5YB NEEDED PER FIXTURE. ALSO PROVIDE WALL MOUNTED J-BOX WITH COVER PLATE FOR MOUNTING.
X9	2	LED CHANNEL LIGHT	SURFACE	EXT'G	EXT'G	PARADIGM LED	AMC-2410-S W/ OPAL LENS AND END CAPS	FLEXSR-45-30-67-24	120		FURNISHED W/ REMOTE-MOUNTED NEMA 3R LED DRIVER. SEE PLAN FOR LENGTHS.

LIGHTING FIXTURE SCHEDULE NOTES

- A. FLUORESCENT LAMPS NOT INCLUDED WITH THE FIXTURE AREA TO BE MANUFACTURED BY SYLVANIA UNLESS OTHERWISE NOTED. PHILIPS FLUORESCENT LAMPS WILL BE AN ACCEPTABLE ALTERNATE.
B. SEE THE ARCHITECTURAL REFLECTED CEILING PLAN FOR EXACT LIGHT LOCATIONS.
C. SEE THE ARCHITECTURAL LIGHTING DETAILS FOR FIXTURE CONSTRUCTION DETAILS.

LIGHTING CONTROL PANEL SCHEDULE: LCP

RELAY	PANEL	CIRCUIT	AREA SERVED	CONTROL	TIME ON	TIME OFF	DIMMER CONTROL	NOTES
R1	A	32	KITCHEN A	TIMECLOCK	7:00:00 AM	12:00:00 AM	N/A	SINGLE POLE (NC)
R2	A	32	KITCHEN B	TIMECLOCK	7:00:00 AM	12:00:00 AM	N/A	SINGLE POLE (NC)
R3			SPARE				N/A	SINGLE POLE (NC)
R4	A	30	DINING ROOM A	TIMECLOCK	10:00:00 AM	12:00:00 AM	N/A	SINGLE POLE (NC)
R5	A	30	DINING ROOM B	TIMECLOCK	10:00:00 AM	12:00:00 AM	N/A	SINGLE POLE (NC)
R6	A	30	DINING ROOM DL	TIMECLOCK	10:00:00 AM	12:00:00 AM	N/A	SINGLE POLE (NC)
R7	A	28	RESTROOM EXHAUST FAN	TIMECLOCK	7:00:00 AM	12:00:00 AM	N/A	SINGLE POLE (NC)
R8	A	42	EXT. LIGHTING/SIGNAGE	TIMECLOCK	SUNSET - 1 HR	12:00:00 AM	N/A	SINGLE POLE (NC)

LIGHTING CONTROL COMPONENTS SCHEDULE


	DESCRIPTION	QUANTITY	FURNISHED BY	INSTALLED BY	MANUFACTURER	MODEL	REMARKS
LCP	WALL-MOUNTED LIGHTING CONTROL PANEL	1	TLS	GC	ACUITY	ARP INTENC08 NLT 8SPR MVOLT FM DTC	8 RELAY PANEL FOR DIMMING CONTROL WITH FLUSH MOUNT ENCLOSURE, AND DIGITAL TIME CLOCK
C	WALL-MOUNTED OVERRIDE SWITCH (4 CHANNEL)	1	TLS	GC	ACUITY	nPODMA 4P WH	SEE LIGHTING CONTROL DIAGRAM FOR SWITCH CONFIGURATION
D	WALL-MOUNTED DIMMER SWITCH	2	TLS	GC	COOPER	SAL06P-W	SLIDE DIMMER COMPATIBLE WITH UP TO 300W LED LIGHTING. SET AT 50%. IF DINING ROOM LIGHTS FLICKER AT THIS DIMMER SETTING THEN GC SHALL PROVIDE LUTRON DVCL-253P DIMMER AS REPLACEMENT.
OC	WALL-MOUNTED LINE VOLTAGE OCCUPANCY SENSOR	2	TLS	GC	HUBBELL	LHMTS 1-N-WH	WHITE DUAL TECHNOLOGY SINGLE RELAY WITH 1 BUTTON AND NEUTRAL WIRING

ELECTRICAL LIGHTING PLAN NOTES

1. INSTALL WALL-MOUNTED LIGHTING OVERRIDE SWITCH AND CONNECT TO LCP AS SHOWN IN DETAIL 6/E710
2. FOR UNCIRCUITED LIGHT FIXTURES, CONNECT TO RELAY CIRCUIT INDICATED NEXT TO THE FIXTURE TAG THROUGH THE LIGHTING CONTROL PANEL (LCP) UNLESS NOTED OTHERWISE.
3. WALL MOUNT THE EMERGENCY LIGHT FIXTURE AT 6" BELOW THE CEILING UNLESS NOTED OTHERWISE
4. VERIFY MOUNTING HEIGHT OF EXIT SIGN PRIOR TO ROUGH IN. EXIT SIGN MUST BE VISIBLE FROM AREA SERVED AFTER BUILDING SYSTEMS HAVE BEEN INSTALLED. SEE ARCHITECTURAL ELEVATIONS FOR FURTHER INFORMATION.
5. RELOCATE LED DRIVERS FURNISHED WITH THE X9 LED STRIP LIGHTS ON WALL 6" ABOVE THE CEILING IN AN ACCESSIBLE LOCATION. PROVIDE LOW VOLTAGE WIRING FROM LED DRIVER TO THE X9 LIGHT FIXTURES AS SHOWN.
6. INSTALL LIGHT FIXTURES FURNISHED WITH THE WALK-IN COOLER. PROVIDE UNSWITCHED CONDUCTOR FROM LIGHTING CIRCUIT TO WALK-IN COOLER LIGHTING J-BOX AND FROM J-BOX TO LIGHT FIXTURES AS SHOWN. CONDUIT BETWEEN LIGHT FIXTURES SHALL BE ROUTED ON THE INTERIOR OF THE WALK-IN COOLER. SEAL INTERIOR AND EXTERIOR OF CONDUITS WHERE THEY PASS THROUGH THE WALK-IN COOLER ENVELOPE PER THE NEC.

ELECTRICAL LIGHTING PLAN NOTES

7. PROVIDE (2) GFCI RECEPTACLES FOR UNDERSHELF LIGHTING AS SHOWN. CONNECT TO SWITCHED LEG OF THE KITCHEN LIGHTING CIRCUIT. SEE ELEVATIONS ON SHEET E700 FOR RECEPTACLE LOCATIONS, HEIGHTS, AND CIRCUITING. INSTALL RECEPTACLES IN A HORIZONTAL ORIENTATION.
8. PROVIDE UNISTRUT AS SHOWN ON THE ARCHITECTURAL RCP PER THE ARCHITECTURAL UNISTRUT DETAIL. TYPICAL.
9. CONNECT EXTERIOR LIGHTING CIRCUIT TO CIRCUIT SHOWN THROUGH THE EXTERIOR LIGHTING CONTACTOR PANEL PER DETAIL 6/E710.
10. INSTALL WALL-MOUNTED OCCUPANCY SENSOR FURNISHED BY LIGHTING SUPPLIER AT 42" AFF. ADJUST OCCUPANCY SENSOR TO PROVIDE AUTOMATIC ON/AUTOMATIC OFF OPERATION WITH A FIXED TIMER OF 30 MINUTES AND WITH BOTH THE PASSIVE INFRARED AND ULTRASONIC SENSORS ENABLED.
11. INSTALL CHIME/STROBE FURNISHED WITH VEHICLE DETECTION SYSTEM ON WALL 12" BELOW CEILING AND CONNECT TO VEHICLE DETECTOR SYSTEM PER THE MANUFACTURER'S INSTALLATION INSTRUCTIONS.
12. INSTALL WALL-MOUNTED DIMMERS ABOVE PANELBOARDS 6" ABOVE LAY-IN CEILING FOR CONTROL OF DINING ROOM OVERHEAD STRIP LED LIGHTS. CONNECT DIMMERS TO RELAYS SHOWN THROUGH THE LIGHTING CONTROL PANEL. SET DIMMERS AT 50%.
13. CONNECT DINING ROOM (RELAY CIRCUITS R4, R5, AND R6) OVERHEAD STRIP LED LIGHTS TO THE RELAY INDICATED THROUGH THE CORRESPONDING WALL-MOUNTED DIMMER INSTALLED ABOVE THE PANELBOARDS.
14. INSTALL LIGHTING CONTROL SYSTEM PER DETAIL 6/E710.

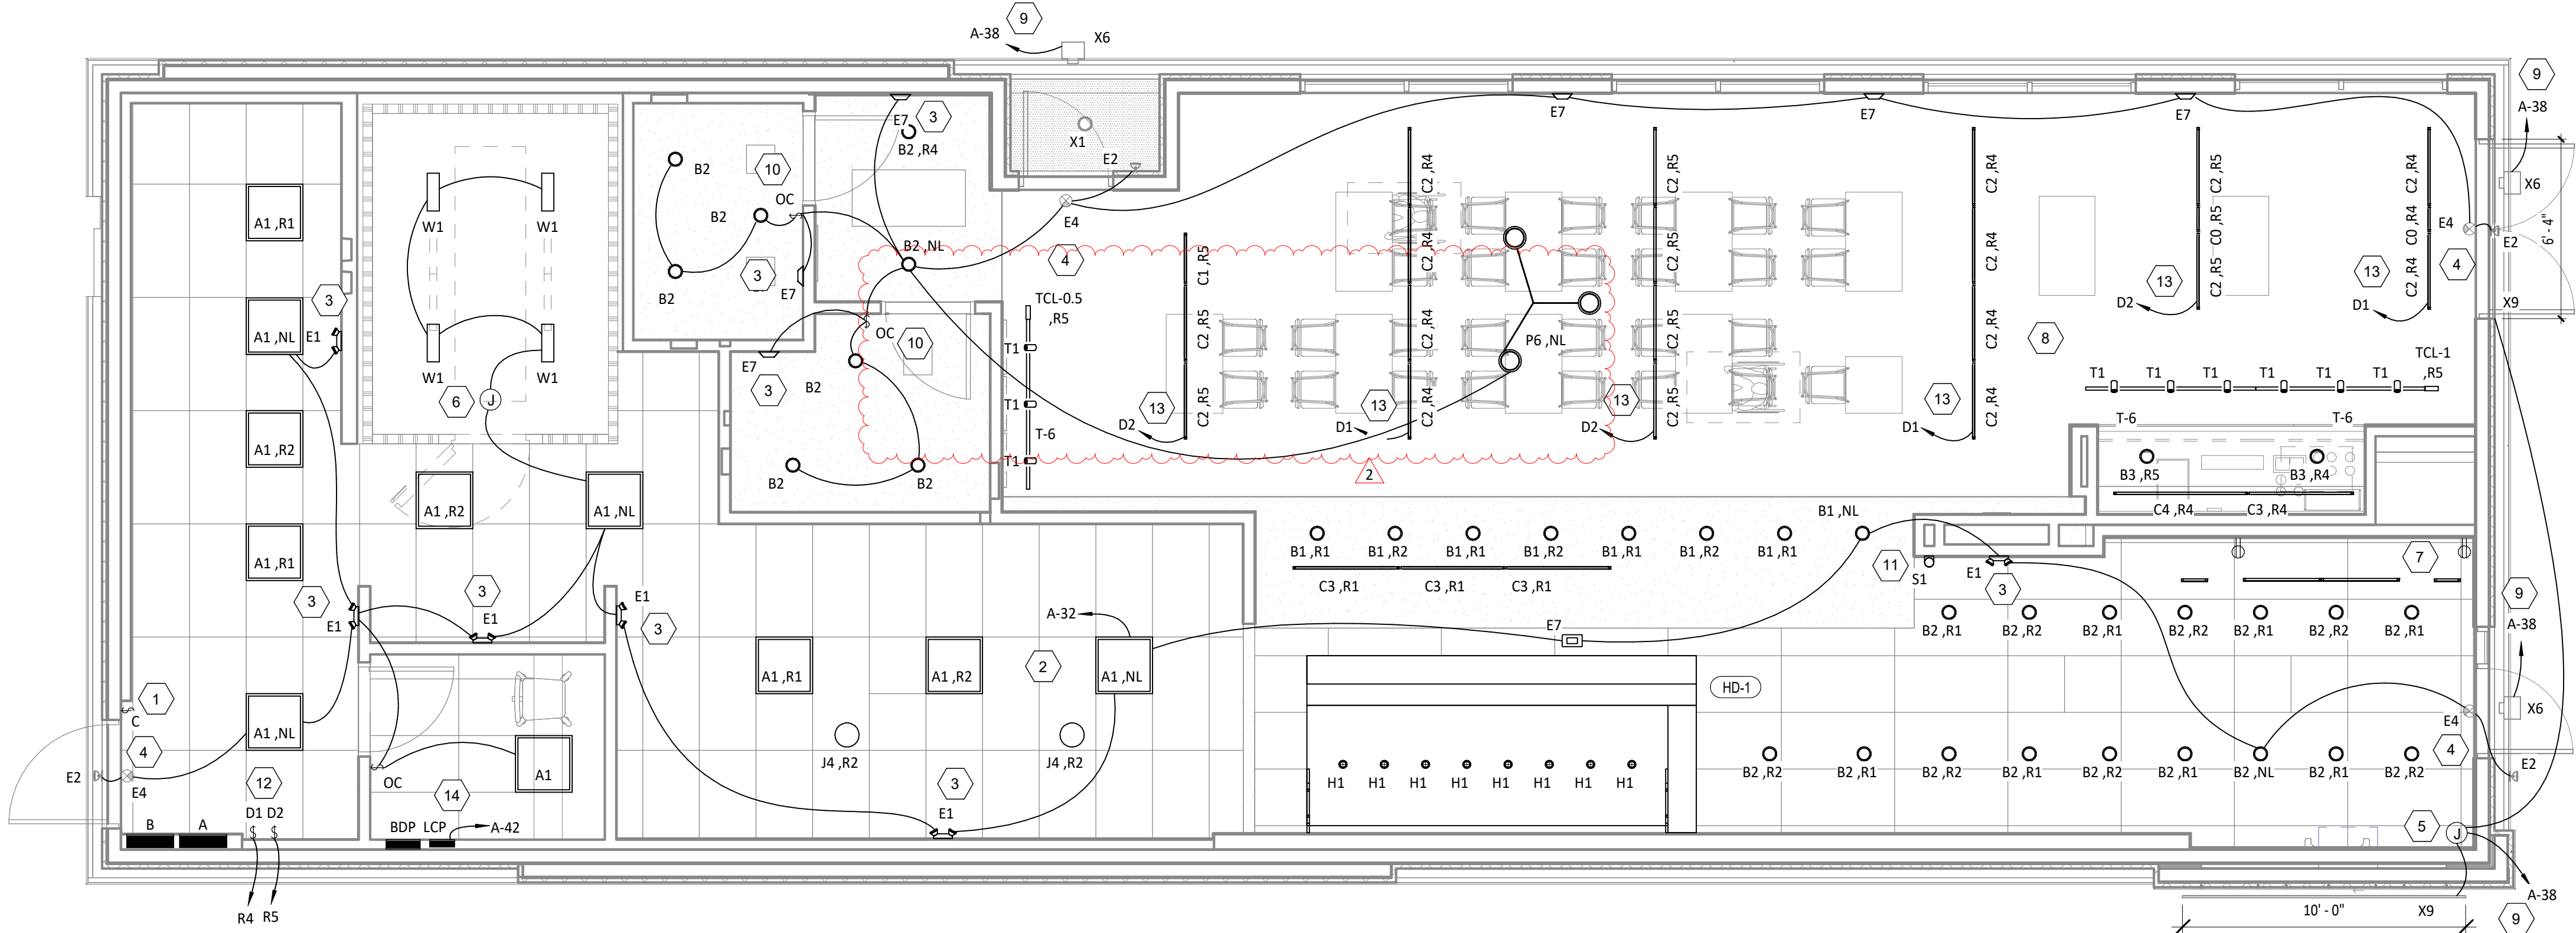

LIGHTING FLOOR PLAN
1/4" = 1'-0"

Consultant:



4635 Trueman Blvd, Suite 250
Hilliard, Ohio 43026
Phone: (614) 751-9610
Fax: (614) 552-5240
Contact: Cliff Kigar
(614) 328-2033
ckigar@nationalengineering.com

FOR CONSTRUCTION

COPYRIGHT 2024
THIS DRAWING IS AN INSTRUMENT OF SERVICE
AND AS SUCH REMAINS THE PROPERTY OF
CHIPOTLE MEXICAN GRILL, INC.. PERMISSION FOR
USE OF THIS DOCUMENT IS LIMITED AND CAN BE
EXTENDED ONLY BY WRITTEN AGREEMENT WITH
CHIPOTLE MEXICAN GRILL, INC..



CHIPOTLE MEXICAN GRILL, INC.
PO BOX 182566
COLUMBUS, OH 43218-2566
TELEPHONE: (614) 318-2400
INTERNET: WWW.CHIPOTLE.COM

STORE NO.: 4870
WALNUT HILLS, OH
1202 E. MCMILLAN
CINCINNATI, OH 45206

Issue Record:
11/03/2023 PERMIT SET
05/08/2024 CONSTRUCTION SET

Revisions:
2 4/25/24 PLAN REVIEW COMMENTS

Drawn: CJK
Checked: JEJ

Project No.
2301004

Contents:

ELECTRICAL
LIGHTING PLAN

E100

1 SHOW ROOM WINDOW RECEPTACLE. COORDINATE EXACT RECEPTACLE MOUNTING HEIGHT IN THE FIELD. LOCATION SHALL BE THE
2 THE DRYWALL IMMEDIATELY ABOVE THE MAIN STORE-FRONT WINDOW AND AS SHOWN IN THE DINING ROOM ELECTRICAL
ELEVATIONS ON SHEET E700.

3 ICE MACHINE ELECTRICAL TIE-IN. COORDINATE EXACT LOCATION WITH EQUIPMENT INSTALLER PRIOR TO ROUGH-IN. PROVIDE
4 L5-20P FLANGED INLET WIRED TO THE REMOTE CONDENSER. PROVIDE 48" CORDS, ONE WITH 5-20P END AND ONE WITH L5-20P
END, FROM ICE MAKER TO RECEPTACLE AND FLANGED INLET.

5 CONNECT RECEPTACLES SERVING EQUIPMENT BELOW THE KITCHEN HOOD TO THE CIRCUITS SHOWN THROUGH THE CONTACTOR
6 INTEGRAL TO THE HOOD CONTROL PANEL. INTEGRAL CONTACTOR SHALL BE INTERLOCKED TO HOOD FIRE PROTECTION SYSTEM
SO THAT RECEPTACLES ARE DE-ENERGIZED UPON ACTIVATION OF HOOD FIRE PROTECTION SYSTEM.

7 JUNCTION BOX FOR EXTERIOR SIGN LIGHTING. COORDINATE EXACT LOCATION WITH CHIPOTLE'S CONSTRUCTION MANAGER AND
8 THE SIGN INSTALLER PRIOR TO ROUGH-IN. CONNECT TO CIRCUIT SHOWN THROUGH THE EXTERIOR LIGHTING CONTACTOR PANEL
AS SHOWN IN DETAIL E67/10.

9 PROVIDE 4" OCTAGONAL JUNCTION BOX WITH SCREW THREADS SET AT THE 2 & 8 O'CLOCK POSITIONS FOR THE ANSUL PULL
10 STATION. PROVIDE A 1/2" CONDUIT FROM THE J-BOX TO 6" ABOVE THE CEILING AND TERMINATE WITH A CONDUIT BUSHING.
COORDINATE EXACT LOCATION WITH THE ANSUL SYSTEM INSTALLER AND THE FIRE MARSHALL PRIOR TO ROUGH-IN.

11 HOOD CONTROL PANEL AND ANSUL CABINET SHALL BE LOCATED WITHIN THE INTEGRAL HOOD UTILITY CABINET. PROVIDE FINAL
12 ELECTRICAL CONNECTIONS PER THE MANUFACTURER'S INSTALLATION INSTRUCTIONS NECESSARY FOR A COMPLETE AND
OPERATIONAL SYSTEM.

13 PROVIDE SINGLE-GANG J-BOX FOR DATA JACK AS SHOWN FOR KRONOS TIME CLOCK.

14 PROVIDE AN EMPTY SINGLE GANG J-BOX FOR VOLUME CONTROLS. INSTALL THE CASK VOLUME CONTROL WIRE FURNISHED BY
15 THE TENANT FROM THE J-BOX TO THE AMPLIFIER IN THE OFFICE WITH 3 FEET OF SLACK AT EACH END.

16 COORDINATE DATA/POWER RECEPTACLE MOUNTING REQUIREMENTS WITH THE CASE WORK INSTALLER PRIOR TO ROUGH-IN.

17 PROVIDE ROUGH-IN FOR LAUNCHPORT AS NOTED. LAUNCHPORT WILL BE FURNISHED AND INSTALLED BY CHIPOTLE WITH THE
18 WALLSTATION AT 62" AFF. PROVIDE A 4" X 2-1/8" DEEP OCTAGON J-BOX WITH 1-1/2" EXTENSION RING AT 62" AFF FOR THE
WALLSTATION INSTALLATION WITH A 1" CONDUIT WITH PULL STRING FROM THE J-BOX TO ABOVE THE OFFICE CEILING.

19 PROVIDE AN EMPTY 1" CONDUIT WITH PULL STRING FROM THE BASE BUILDING'S TELEPHONE SERVICE ENTRANCE LOCATION TO
20 THE SPACE ABOVE THE OFFICE CEILING.

21 PROVIDE A SUITABLE LENGTH OF LIQUID-TIGHT CONDUIT TO THE EXHAUST FAN EF-1 TO ALLOW THE EXHAUST FAN TO HINGE
COMPLETELY OPEN WHEN THE VIROGUARD SYSTEM IS INSTALLED.

22 AFTER THE FAX LINE, POS, AND OFFICE EQUIPMENT IS INSTALLED PROVIDE CHILDPROOF RECEPTACLE COVERS ON UNUSED IG
23 RECEPTACLES AT THE FAX LINE, POS, AND OFFICE.

24 PROVIDE ONE PHASE, ONE NEUTRAL, AND ONE GROUND CONDUCTOR FROM THE ICE MAKER TO THE REMOTE CONDENSING
UNIT.

25 UNIT SHALL HAVE AN INTEGRAL NON-FUSED DISCONNECT SWITCH.

26 PROVIDE 3" CONDUIT (EMT, IMC, OR RMC) THROUGH ROOF. TERMINATE WITH WEATHERHEAD 12" ABOVE ROOF FOR FUTURE
CELL BOOSTER.

27 INSTALL THE BYPASS DISTRIBUTION PANEL (BDP) FURNISHED BY THE TENANT. INSTALL PER THE MANUFACTURER'S INSTALLATION
28 INSTRUCTIONS AND DETAIL 3/EP/10.

29 ROUGH-INS TO SERVE LINE AND POS EQUIPMENT ARE UNDERGROUND. COORDINATE ROUGH-IN REQUIREMENTS AND
30 LOCATIONS WITH EQUIPMENT MANUFACTURER PRIOR TO ROUGH-IN.

31 ROOFTOP UNIT SHALL HAVE AN INTEGRAL UNIT-MOUNTED GFCI RECEPTACLE. PROVIDE CONNECTION TO CIRCUIT SHOWN.

32 ICE MAKER RECEPTACLES SHALL BE CONCEALED BEHIND THE ICE MAKER. COORDINATE LOCATION WITH ACTUAL WIDTH OF ICE
MAKER.

33 PROVIDE VERDICAL METAL DIE CAST WEATHERPROOF WHILE IN USE OUTLET COVER ON RECEPTACLES AT COOK LINE. COVER
34 SHALL BE INTERMATIC WP1010MXD FOR SINGLE GANG BOXES AND WP1030MXD FOR DOUBLE GANG BOXES. NO SUBSTITUTIONS
SHALL BE ACCEPTED.

35 LABEL BATTERY-PROTECTED RECEPTACLES "BATTERY-PROTECTED: DISCONNECT AT PANEL BDP".

36 LABEL MAIN DISCONNECT SWITCH AND PANEL A "WARNING: BATTERY-PROTECTED RECEPTACLES IN USE. DISCONNECT AT PANEL
BDP."

37 PROVIDE JUNCTION BOX FOR POWER INLET AND OUTLET TO THE UPS. CONNECT POWER TO THE UPS PER THE MANUFACTURER'S
38 DIRECTIONS.

39 CONNECT RESTROOM EXHAUST FAN TO CIRCUIT SHOWN THROUGH THE LIGHTING CONTROL PANEL (LCP).

INSTALL 16/2 SPEAKER WIRE FURNISHED BY OWNER. INSTALL SPEAKER WIRE BETWEEN SPEAKERS IN THE DINING ROOM AS SHOWN AND TO THE AMPLIFIER IN THE OFFICE WITH THE REE FEE SLACK AT EACH END. THERE SHALL BE TWO SPEAKER WIRE HOMERUNS WITH TWO SPEAKERS ON EACH HOMERUN. SEE ARCHITECTURAL PLANS FOR SPEAKER LOCATIONS. ADJUST EACH SPEAKER 70V TAP SETTING TO BE 15 WATTS.

PROVIDE POWER CONNECTIONS TO ISLAND PREP TABLE PER DETAIL 2/E7/10. PROVIDE GFCI DUPLEX RECEPTABLES IN THREE J-BOXES INTEGRAL TO PREP TABLES (FOR UNDERCOUNTER REFRIGERATOR, HOT HOLDING CABINET, AND GENERAL RECEPTACLE).

PROVIDE GFCI RECEPTACLE AND J-BOX AND INSTALL CO2 ALARM FURNISHED BY CO2AS AS SHOWN IN DETAIL 4/E7/10.

PROVIDE J-BOX AND INSTALL CO2 ALARM REMOTE DISPLAY UNIT FURNISHED BY CO2AS AS SHOWN IN DETAIL 4/E7/10.

INSTALL WALK-IN-COOLER EXTERNAL READOUT THERMOMETER REMOTE PROBE ON WALL OPPOSITE FROM DOOR AS SHOWN. ROUTE TEMPERATURE PROBE WIRE ABOVE WALK-IN COOLER CEILING PANELS, SLAT PENETRATIONS THROUGH THE CEILING PANELS, AND SECURE VERTICAL PROBE WIRE TIGHT TO WALLS. NO EXCESS PROBE WIRE SHALL BE WITHIN THE WALK-IN COOLER.

PROVIDE RECEPTACLE FOR RESTROOM HAND SINK FAUCET AS SHOWN IN DETAIL 14/P700.

PROVIDE A TWO-CONDUCTOR LOW VOLTAGE WIRE IN 3/4" C. AND (4) #12, #10, #12 G. IN 1" C. FROM MAU-1 TO THE HOOD CONTROL PANEL PER THE MANUFACTURER'S INSTALLATION INSTRUCTIONS.

PROVIDE 1" CONDUITS FROM LOW-VOLTAGE J-BOXES AT POS COUNTER CONCEALED WITHIN THE SERVE LINE WIRING CHASE TO THE WALL, THEN CONCEALED WITHIN THE WALL AND ABOVE THE CEILING TO ABOVE THE OFFICE CEILING.

IF NEUTRAL CONDUCTOR IS NOT NEEDED FOR SERVE LINE HOT FIRE SERVICE TERMINATE NEUTRAL IN JUNCTION BOX.

LABEL UTENSIL COUNTER RECEPTABLES "TRACTOR BEVERAGE", "ICE MAKER/IMSB", AND "SODA FOUNTAIN".

PROVIDE CORD AND NEMA 5-20P PLUG FROM UTENSIL COUNTER ICE MAKER, THROUGH UTENSIL COUNTER, TO ICE MAKER RECEPTACLE.

LABEL RECEPTACLE "UV INSECT TRAP".

INSTALL TRANSFORMER FURNISHED BY TUV WITH THE REE HALO AIR PURIFIER IN THE JUNCTION BOX ON THE EXTERIOR OF THE RTU RUNS DETAIL 6/W700. CONNECT LINE SIDE OF THE TRANSFORMER TO THE RTU SERVICE RECEPTACLE CIRCUIT SO THAT REE HALO PER CONTINUOUSLY. CONNECT THE LOW VOLTAGE SIDE OF THE TRANSFORMER TO THE REE HALO USING THE INCLUDED BARREL PLUG.

PROVIDE (2) 10"x10"x4" JUNCTION BOXES (J-BOX #11-J-BOX #2) ON THE WALL ABOVE PANELBOARDS 6" BELOW THE LAY-IN CEILING AND MOUNTED ADJACENT TO EACH. PROVIDE CONDUITS AND WIRING SHOWN IN DETAIL 8/E7/10. TEMS SHALL PROVIDE GRIDPOINT 3 PHASE METER AND TRANSFORMER WITHIN J-BOX #1 AND GRIDPOINT IOM/HUB WITHIN J-BOX #2. SEE GRIDPOINT INSTALLATION SHEET FOR DETAILS.

PROVIDE HORIZONTAL SINGLE-GANG J-BOX BELOW FUTURE GRIDPOINT CONTROLLER LOCATION. PROVIDE CONDUITS AND WIRING AS SHOWN IN DETAIL 8/E7/10.

INSTALL WIRED DOOR BUZZER AT 96" AFF. SEE ARCHITECTURAL DOOR EQUIPMENT FOR EQUIPMENT INFORMATION. CONNECT TO CIRCUIT SHOWN THROUGH THE TRANSFORMER FURNISHED WITH THE DOOR BUZZER. PROVIDE WIRING TO A BUTTON ADJACENT TO THE SERVICE DOOR AND CONNECT PER THE MANUFACTURER'S INSTALLATION INSTRUCTIONS.

CONNECT BATHROOM SANITIZER TO CIRCUIT SHOWN SO THAT IT IS ENERGIZED AT ALL TIMES.

PROVIDE POWER AND LOW VOLTAGE CONNECTIONS TO DISH SANITIZING MACHINE PER DETAIL 7/E7/10. CONNECT THE DETERGENT DISPENSER TO THE DISH MACHINE USING THE INCLUDED WIRING HARNESS PER THE MANUFACTURER'S INSTALLATION INSTRUCTIONS.


PROVIDE RECEPTACLE FOR 2-DOOR AND/OR 1-DOOR REFRIGERATOR WITH GROUND PINS TOWARDS THE BOTTOM OF THE RECEPTACLE.

PROVIDE ISLAND PREP TABLE FOOD WARMER RECEPTABLE WITH GROUND PIN TOWARDS THE BOTTOM OF THE RECEPTACLE.


SEAL INTERIOR AND EXTERIOR OF CONDUITS THAT PASS THROUGH THE WALK-IN COOLER ENVELOPE PER THE NEC.

INSTALL VEHICLE DETECTOR SYSTEM FURNISHED BY TLS SURFACE-MOUNTED ON WALL ABOVE CEILING IN ACCESSIBLE LOCATION CONNECT TO STROBE/CHIME AND DETECTOR LOOP PER THE MANUFACTURER'S INSTALLATION INSTRUCTIONS. MAKE FINAL ADJUSTMENTS TO LOOP SENSITIVITY PER THE MANUFACTURER'S INSTRUCTIONS. ONCE ALL COMPONENTS ARE INSTALLED AND OPERATIONAL THE CHIME/STROBE LIGHT SHOULD STAY ILLUMINATED AND THERE SHOULD BE A SINGLE CHIME WHEN A VEHICLE DRIVES OVER OR STOPS ON LOOP.

PROVIDE 4" SQUARE J-BOX ON EXTERIOR WALL FOR MOUNTING OF EXTERIOR CAMERA. SEE ARCHITECTURAL ELEVATION FOR EXACT HEIGHT AND LOCATION. PROVIDE 3/4" CONDUIT WITH PULLSTRING FROM J-BOX TO ABOVE LAY-IN CEILING AREA IN KITCHEN. J-BOX SHALL NOT BE SURFACE MOUNTED. BASE OF CAMERA SHALL BE MOUNTED FLUSH TO EXTERIOR WALL FINISH.

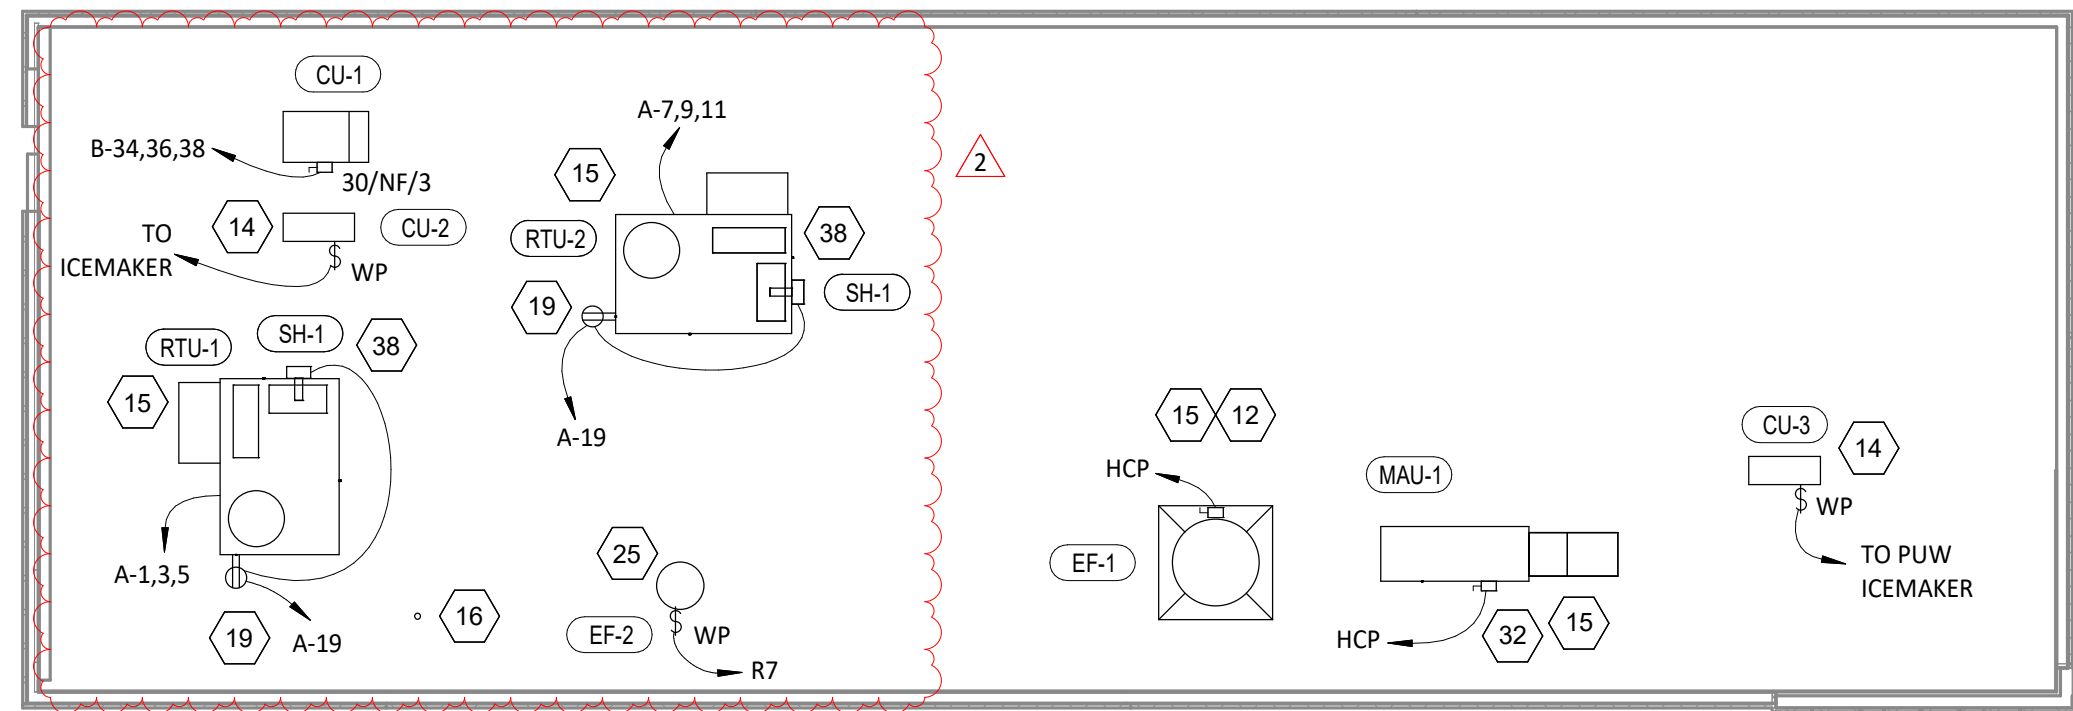

 **POWER ROOF PLAN**
1/8" = 1'-0"


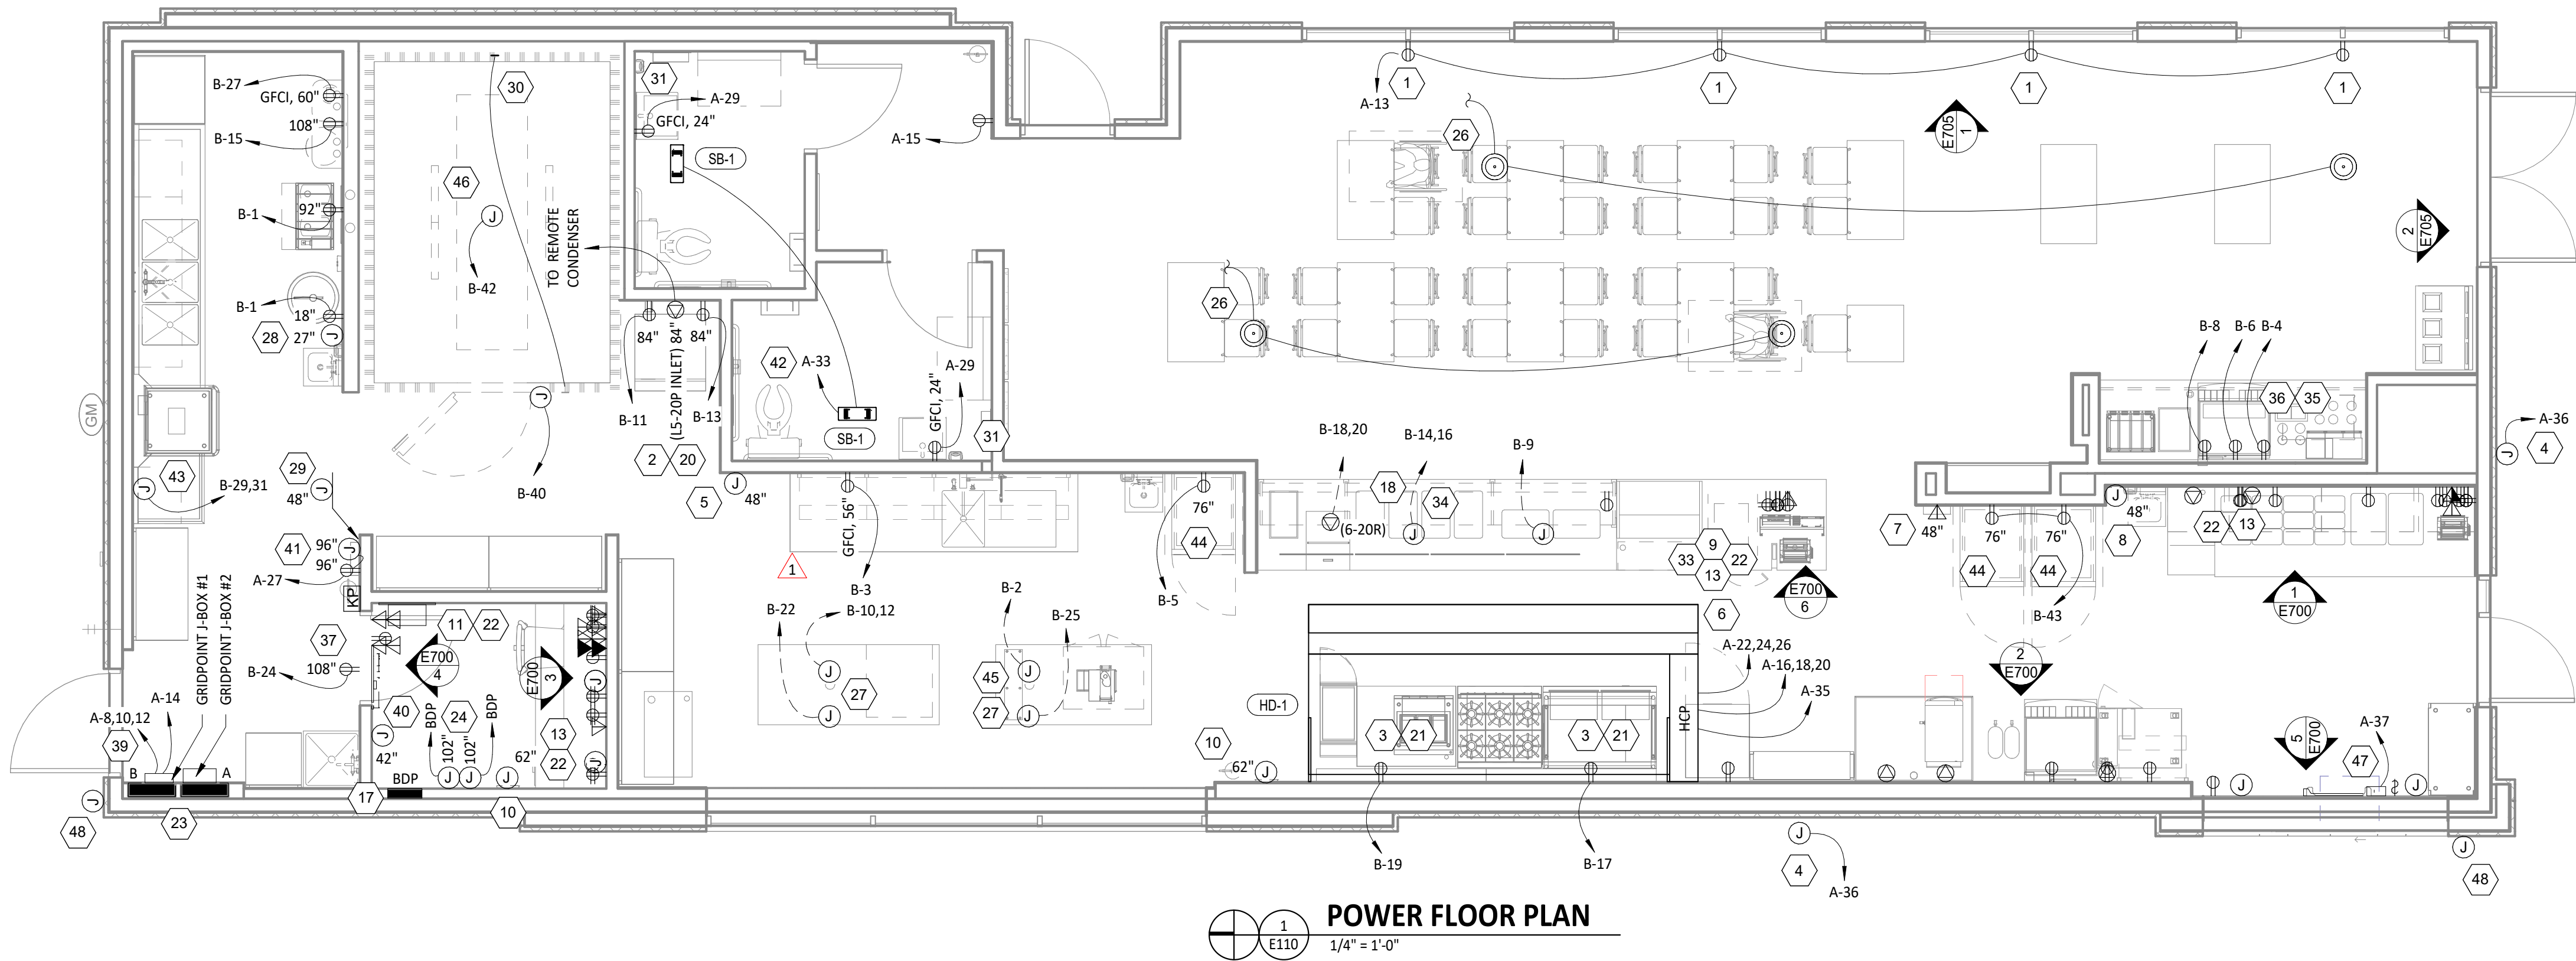


FOR CONSTRUCTION

The logo for Chipotle Mexican Grill, featuring a circular emblem with a stylized chili pepper in the center. The word "CHIPOTLE" is written in an arc above the pepper, and "MEXICAN GRILL" is written in an arc below it, separated by small dots.

STORE NO.: 4870
WALNUT HILLS, OH
1202 E. MCMILLAN
CINCINNATI, OH 45206

E110

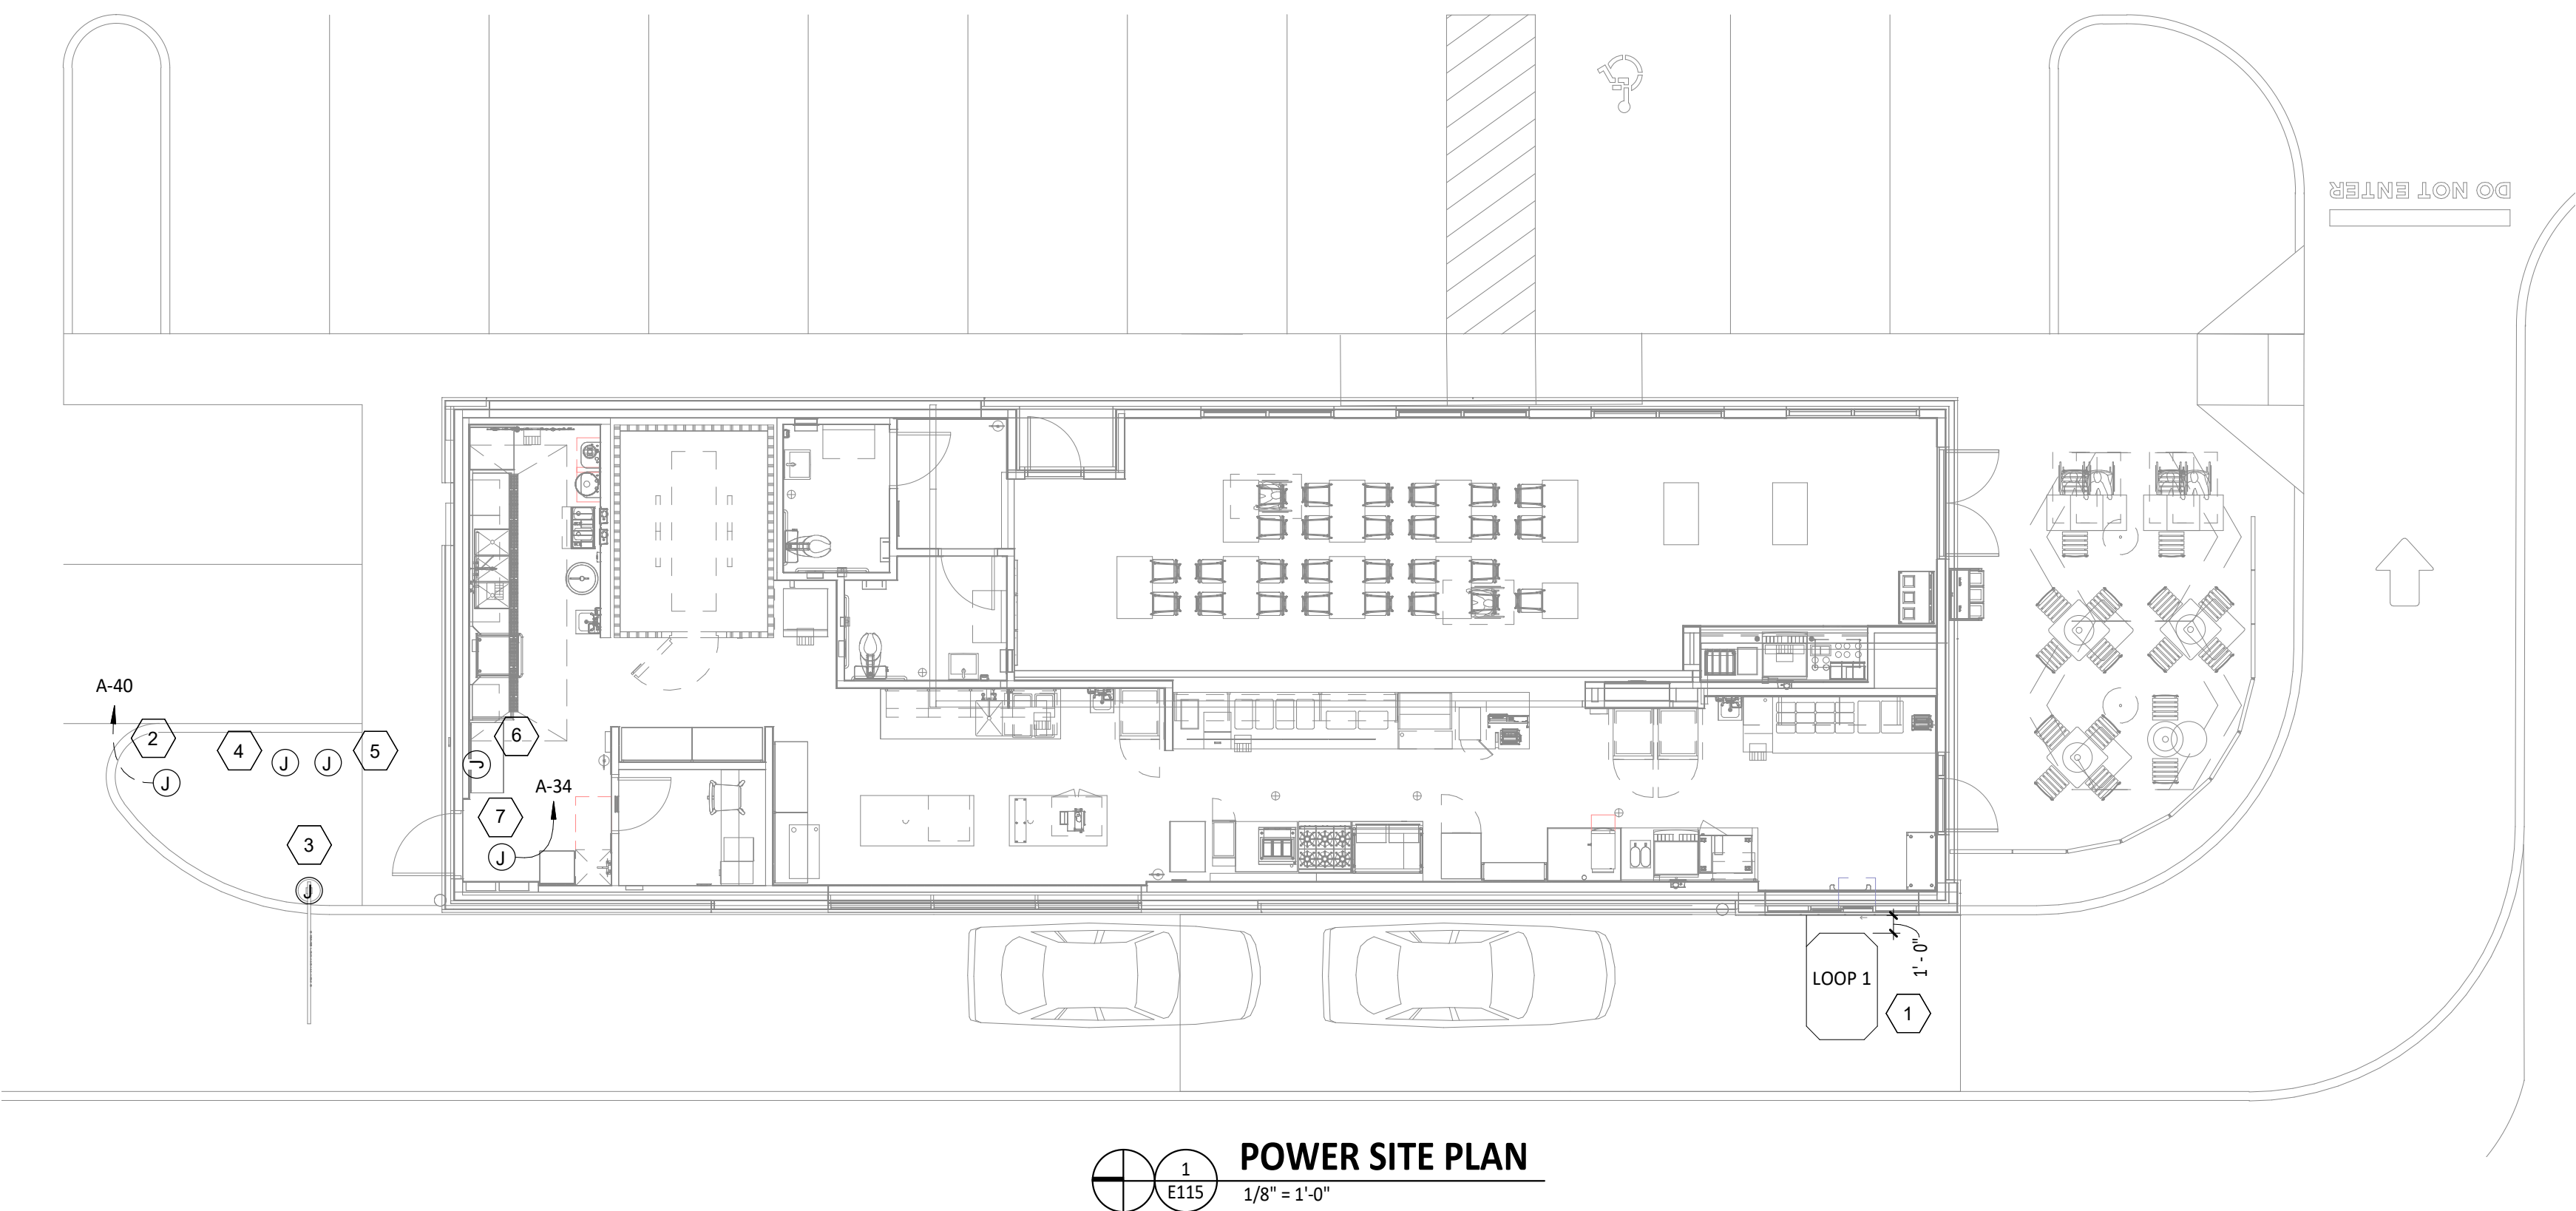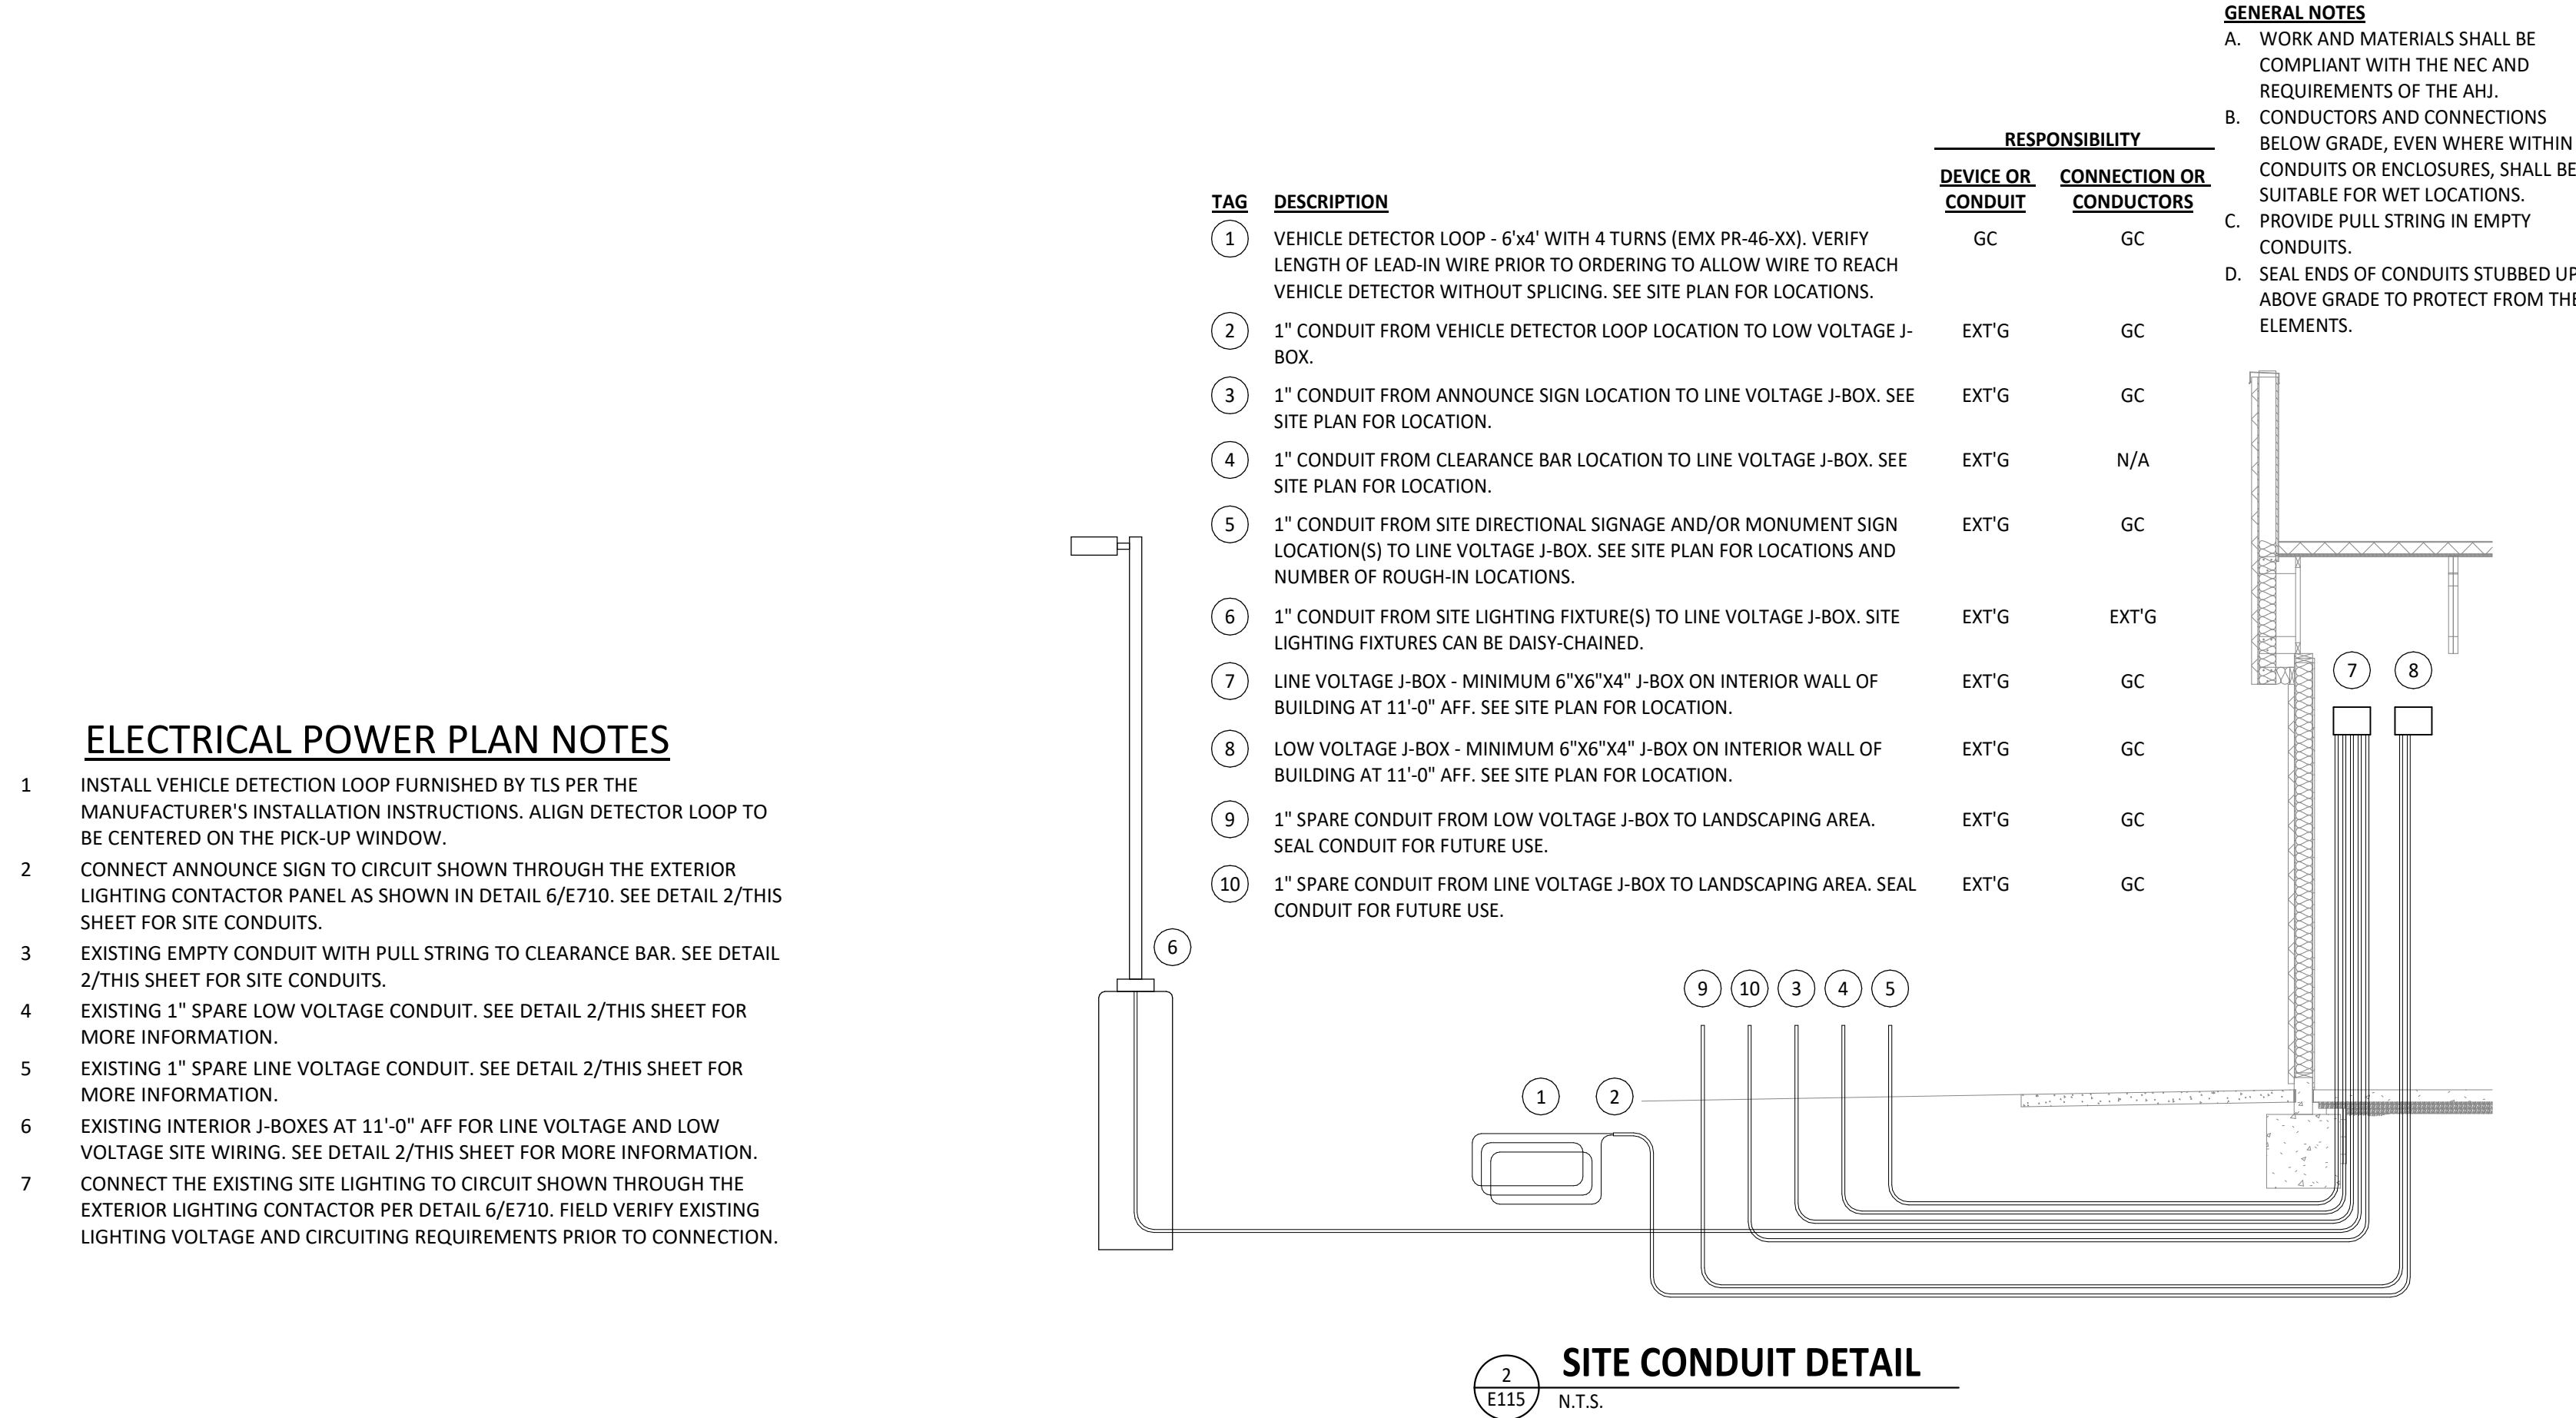

Consultant:

NATIONAL
ENGINEERING

4635 Trueman Blvd, Suite 250
Hilliard, Ohio 43026
Phone: (614) 751-9610
Fax: (614) 552-5240
Contact: Cliff Kigar
(614) 328-2033
ckigar@nationalengineering.com

FOR CONSTRUCTION

COPYRIGHT 2024
THIS DRAWING IS AN INSTRUMENT OF SERVICE
AND AS SUCH REMAINS THE PROPERTY OF
CHIPOTLE MEXICAN GRILL, INC.. PERMISSION FOR
USE OF THIS DOCUMENT IS LIMITED AND CAN BE
EXTENDED ONLY BY WRITTEN AGREEMENT WITH
CHIPOTLE MEXICAN GRILL, INC..



CHIPOTLE MEXICAN GRILL, INC.
PO BOX 182566
COLUMBUS, OH 43218-2566
TELEPHONE: (614) 318-2400
INTERNET: WWW.CHIPOTLE.COM

STORE NO.: 4870
WALNUT HILLS, OH
1202 E. MCMILLAN
CINCINNATI, OH 45206

Issue Record:
11/03/2023 PERMIT SET
05/08/2024 CONSTRUCTION SET

Revisions:
2 4/25/24 PLAN REVIEW COMMENTS

Drawn: CJK
Checked: JEJ

Project No.
2301004

Contents:







ELECTRICAL SITE
POWER PLAN

E115

Panel Name: BDP		Volts: 120		Mains: LUGS	
Mounting: Recessed		Phases: 1		Amperage: 20 A	
Enclosure: Type 1		Wires: 2			
CKT	Circuit Description		Trip	Poles	Load
1	POS		15 A	1	0.2 kVA
2	DML - POS		15 A	1	0.2 kVA
3	DML - ORDERING SYSTEM		15 A	1	0.7 kVA
4	OFFICE - SECURITY SYSTEM		15 A	1	0.2 kVA
5	OFFICE - COMPUTER		15 A	1	0.4 kVA
6	OFFICE - DVR/ISP		15 A	1	0.5 kVA
Total Load:				2.2 kVA	
Total Amps:				18 A	

VOLTS: 208/120V Wye																	
PHASES: 3																	
WIRES: 4																	
MOUNTING: Recessed																	
ENCLOSURE: Type 1																	
PANEL: A																	
MAINS: MCB																	
AMPERAGE: 400 A																	
MCB RATING: 400 A																	
CKT #	DESCRIPTION	C/B [A]	# PLS	NOTES	LOAD [A]	LOAD TYPE	LOAD [kVA] A	LOAD [kVA] B	LOAD [kVA] C	LOAD TYPE	LOAD [A]	NOTES	# PLS	C/B [A]	DESCRIPTION	CKT #	
1	AIR CONDITIONER - KITCHEN (RTU-1) (3-#6, #10 G. IN 1" C.)	60	3	HACR	49.0	C	5.9	0.0		-	0.0		3	60	TVSS (4-#6, #10 G. IN 1" C.)	2	
3								5.9	0.0							4	
5									5.9							0.0	6
7							5.9	0.0									
9	AIR CONDITIONER - DINING ROOM (RTU-2) (3-#6, #10 G. IN 1" C.)	60	3	HACR	49.0	C		5.9	0.0	-	0.0		3	20	GRIDPOINT 3 PHASE METER (4-#12, #12 G. IN 3/4" C.)	10	
11									5.9							0.0	12
13	RECEPTACLES - STOREFRONT Receptáculos - Frente del restaurante	20	1		6.0	G	0.7	0.2		G	1.5		1	20	GRIDPOINT TRANSFORMER	14	
15	RECEPTACLES - DINING Receptáculos - Comedor	20	1		1.5	G		0.2	1.2							16	
17	Panel BDP	20	1		18.0	G			2.2	1.2	E	10.4	3	20	HOOD EXHAUST FAN (EF-1) (3-#12, #12 G. IN 3/4" C.)	18	
19	RECEPTACLES - ROOFTOP Receptáculos - Techo	20	1		3.3	G, E	0.4	1.2								20	
21	RECEPTACLES - POS GENERAL Receptáculos - Cajero general	20	1		6.0	G		0.7	0.5							22	
23	SECURITY/AUDIO Seguridad y audio	20	1		3.0	G			0.4	0.5	E	3.9	3	15	HOOD MAKEUP AIR FAN (MAU-1) (3-#12, #12 G. IN 3/4" C.)	24	
25	SPARE	20	1	--	--		0.0	0.5								26	
27	RECEPTACLES - OFFICE Receptáculos - Oficina	20	1	GFCI	9.0	G			1.1	0.5	A, E	4.4	1	15	RESTROOM FAN (EF-2)	28	
29	RECEPTACLES - RESTROOMS Receptáculos - Baños	20	1		3.0	G			0.4	0.6	A	4.8	1	20	LIGHTING - DINING ROOM Iluminación - Comedor	30	
31	RECEPTACLES - DML Receptáculos - Fax	20	1	GFCI	6.9	G	0.8	1.5			A	12.9	1	20	LIGHTING - KITCHEN Iluminación - Cocina	32	
33	BATHROOM SANITIZER Sanitizante de baño	20	1		0.2	E		0.0	0.1		B	0.8	1	20	EXISTING SITE LIGHTING	34	
35	HD-1 (CONTROL AND LIGHTS) (control y luces)	15	1		1.5	E			0.2	0.3	B	2.7	1	20	SIGN LIGHTING Iluminación para letreros	36	
37	PICK UP WINDOW NOTIFICATION	20	1		0.3	G	0.0	0.1			A, B	0.6	1	20	LIGHTING - EXTERIOR Iluminación - Exterior	38	
39	SPARE	20	1	--	--			0.0	0.1		B	0.8	1	20	SITE SIGNAGE	40	
41	SPARE	20	1	--	--				0.0	0.0	A	0.0	1	20	LIGHTING CONTROL PANEL	42	
43	SPARE	20	1	--	--	0.0	0.2				E	1.5	1	20	PICK-UP WINDOW	44	
45	SPARE	20	1	--	--			0.0	2.1							46	
47	SPARE	20	1	--	--				0.0	2.1	D	20.2	2	25	PUW AIR CURTAIN (2-#10, #10 G. IN 3/4" C.)	48	
49	SPARE	20	1	--	--	0.0	0.0				--	--	1	20	SPARE	50	
51	SPARE	20	1	--	--			0.0	0.0		--	--	1	20	SPARE	52	
53	SPARE	20	1	--	--				0.0	0.0	--	--	1	20	SPARE	54	
FEED THRU (PANEL B) (4-500 KCMIL, #1/8 G. IN 4" C.)							0	3	LUGS	154.2	SPARE: F						
PHASE TOTAL [kVA]:							36.8 kVA	36.8 kVA	37.2 kVA								
PHASE TOTAL [AMPS]:							307 A	307 A	310 A								
TYPE	DESCRIPTION	CONNECTED LOAD		DEMAND FACTOR		ESTIMATED DEMAND		PANEL TOTALS									
A	INTERIOR LIGHTING	2 kVA		125.00%		3 kVA		TOTAL CONNECTED kVA: 111 kVA									
B	EXTERIOR LIGHTING	1 kVA		125.00%		1 kVA		TOTAL CONNECTED AMPS: 308 A									
C	COMFORT COOLING	35 kVA		100.00%		35 kVA		TOTAL ESTIMATED kVA: 92.1 kVA									
D	COMFORT HEATING	4 kVA		100.00%		4 kVA		TOTAL ESTIMATED AMPS: 256 A									
E	MISC. MOTOR	6 kVA		100.00%		6 kVA											
F	KITCHEN EQUIPMENT	56 kVA		65.00%		36 kVA											
G	RECEPTACLES	7 kVA		100.00%		7 kVA											

VOLTS: 208/120V Wye											PANEL: B						
PHASES: 3											MAINS: LUGS						
WIRES: 4											AMPERAGE: 400 A						
MOUNTING: Recessed											MCB RATING: 0 A						
ENCLOSURE: Type 1																	
CKT #	DESCRIPTION	C/B [A]	# PLS	NOTES	LOAD [A]	LOAD TYPE	LOAD [kVA] A	LOAD [kVA] B	LOAD [kVA] C	LOAD TYPE	LOAD [A]	NOTES	# PLS	C/B [A]	DESCRIPTION	CKT #	
1	CARBONATOR/CO2 ALARM Sistema de carbonatación y alarma de CO2	20	1	GFCI	10.9	F	1.3	1.4		F	11.3		1	20	FOOD PREP TABLE (ISLAND) Mesa para la preparación de alimentos (isla)	2	
3	FOOD PREP TABLE Mesa para la preparación de alimentos	20	1		11.3	F		1.4	1.1	F	9.4	GFCI	1	20	SODA SYSTEM DISPENSER Dispensador para el sistema de refrescos	4	
5	UPRIGHT REFRIGERATOR - 1 DOOR Refrigerador vertical	20	1	GFCI	5.0	F			0.6	1.4	F	12.0	GFCI	1	20	ICE MAKER - UTENSIL COUNTER Máquina para hacer hielo	6
7	READY-TO-DRINK REFRIGERATOR	20	1	GFCI	8.8	F	1.1	1.0		F	8.5	GFCI	1	20	BUBBLER	8	
9	COLD TOP (SERVE LINE) Tabla fría (línea de servicio)	20	1		12.0	F		1.4	1.0								
										F	10.0		2	20	CARVING STATION Estación para cortar carnes	10	
									0.2	1.0						12	
11	ICE MAKER Máquina para hacer hielo	20	1	GFCI	1.5	F											
13	ICE MAKER Máquina para hacer hielo	20	1	GFCI	16.0	F	1.9	2.1									
										F	20.0		2	30	HOT FOOD SERVER (SERVE) (2-#10, #10 N, #10 G, in 3/4" C.) Servidor de alimentos	14	
15	GAS WATER HEATER Calentador de agua a gas	20	1	gfci	5.0	F		0.6	2.1							16	
17	GAS GRIDDLE Plancha de gas	20	1	GFCI	1.5	F			0.2	1.4							
										F	13.0	GFCI	2	20	TORTILLA PRESS (SERVE LINE) (2-#10, #10 G, in 3/4" C.) Calentador de tortillas	18	
19	GAS FRYER Freidora de gas	20	1	GFCI	0.6	F	0.1	1.4								20	
21	TORTILLA PRESS (SML) (2-#10, #10 G, in 3/4" C.) Calentador de tortillas (línea del fax)	20	2	GFCI	13.0	F		1.4	0.3		F	2.6	1	20	REFRIGERATOR (COOK LINE) Refrigerador (línea para cocinar)	22	
23									1.4	0.2	F	1.5	GFCI	1	20	UV INSECT LIGHT TRAP	24
25	FOOD WARMER (RICE TABLE) Calentador de alimentos (mesa para el arroz)	15	1		1.5	F	0.2	1.4			F	11.7	GFCI	1	20	FOODWARMER (SML) Calentador de alimentos (línea de fax)	26
27	WATER SOFTENER	20	1		1.5	F		0.2	2.1								
										F	20.0	GFCI	2	30	HOT FOOD SERVER (SML) (2-#10, #10 N, #10 G, in 3/4" C.) Servidor de alimentos calientes (línea de fax)	28	
29	DISH MACHINE (2-#10, #10 G, in 3/4" C.) Lavavajillas	30	2		25.0	F			2.6	2.1						30	
31							2.6	1.2			F	10.0	GFCI	1	20	COLD TOP (SML) Tabla fría (línea de fax)	32
33								2.9	0.8							34	
35	QUESADILLA MAKER - PUW (2-#10, #10 G, in 3/4" C.)	30	2	GFCI	28.0	F				2.9	0.8	F	6.5	3	15	CU-1 (3-#10, #10 G, in 3/4" C.)	36
37	UNDERCOUNTER COOLER (PUW)	20	1	GFCI	3.0	F	0.4	0.8								38	
39	QUESADILLA MAKER - PUW (2-#10, #10 G, in 3/4" C.)	30	2	GFCI	28.0	F		2.9	0.2		F	1.6	1	20	WIC - EVAPORATOR	40	
41									2.9	0.0	F	0.2	1	20	WIC - DOOR	42	
43	UPRIGHT REFRIGERATOR - 1 DOOR Refrigerador vertical	20	1	GFCI	10.0	F	1.2	1.5			F	12.5	GFCI	1	20	ICE MAKER (PUW) Máquina para hace hielo	44
45	SODA SYSTEM DISPENSER (PUW)	20	1	GFCI	1.5	F		0.2	0.0	--	--		1	20	SPARE	46	
47	SPARE	20	1	--	--				0.0	0.0	--	--	1	20	SPARE	48	
49	SPARE	20	1	--	--	0.0	0.0				--	--	1	20	SPARE	50	
51	SPARE	20	1	--	--			0.0	0.0		--	--	1	20	SPARE	52	
53	SPARE	20	1	--	--				0.0	0.0	--	--	1	20	SPARE	54	
PHASE TOTAL [kVA]:							19.4 kVA	18.5 kVA	17.6 kVA								
PHASE TOTAL [AMPS]:							163 A	156 A	147 A								

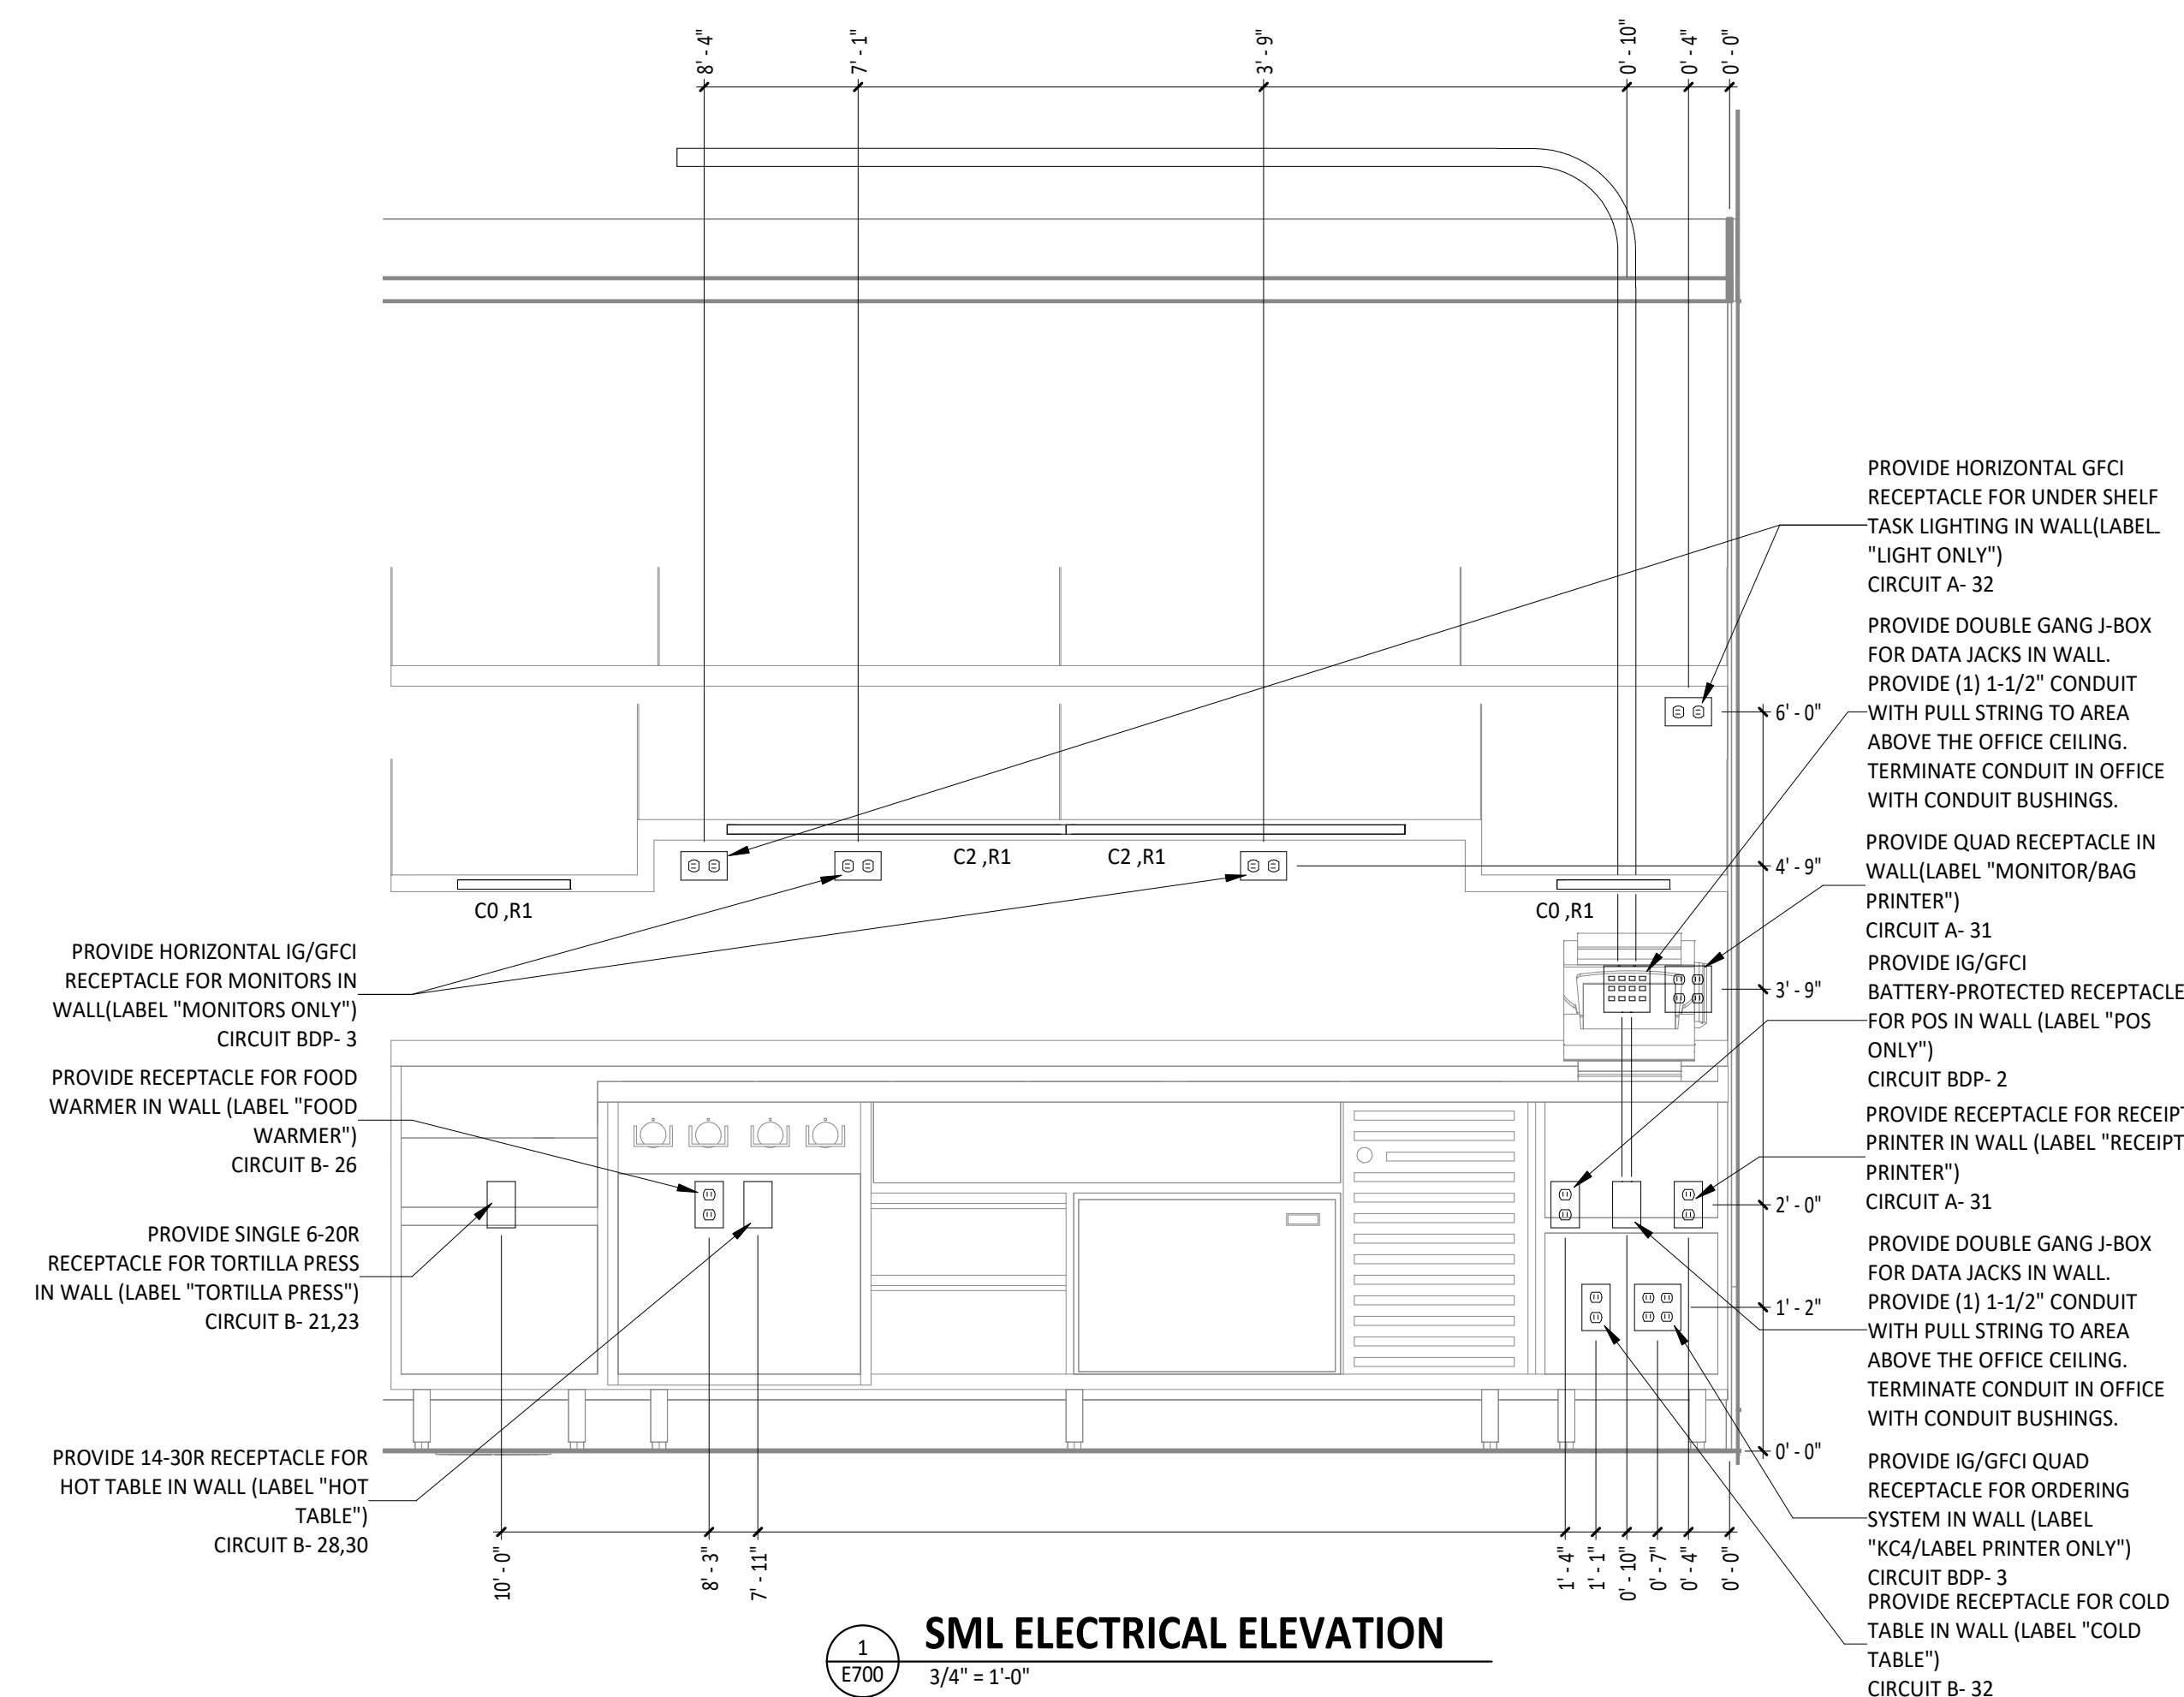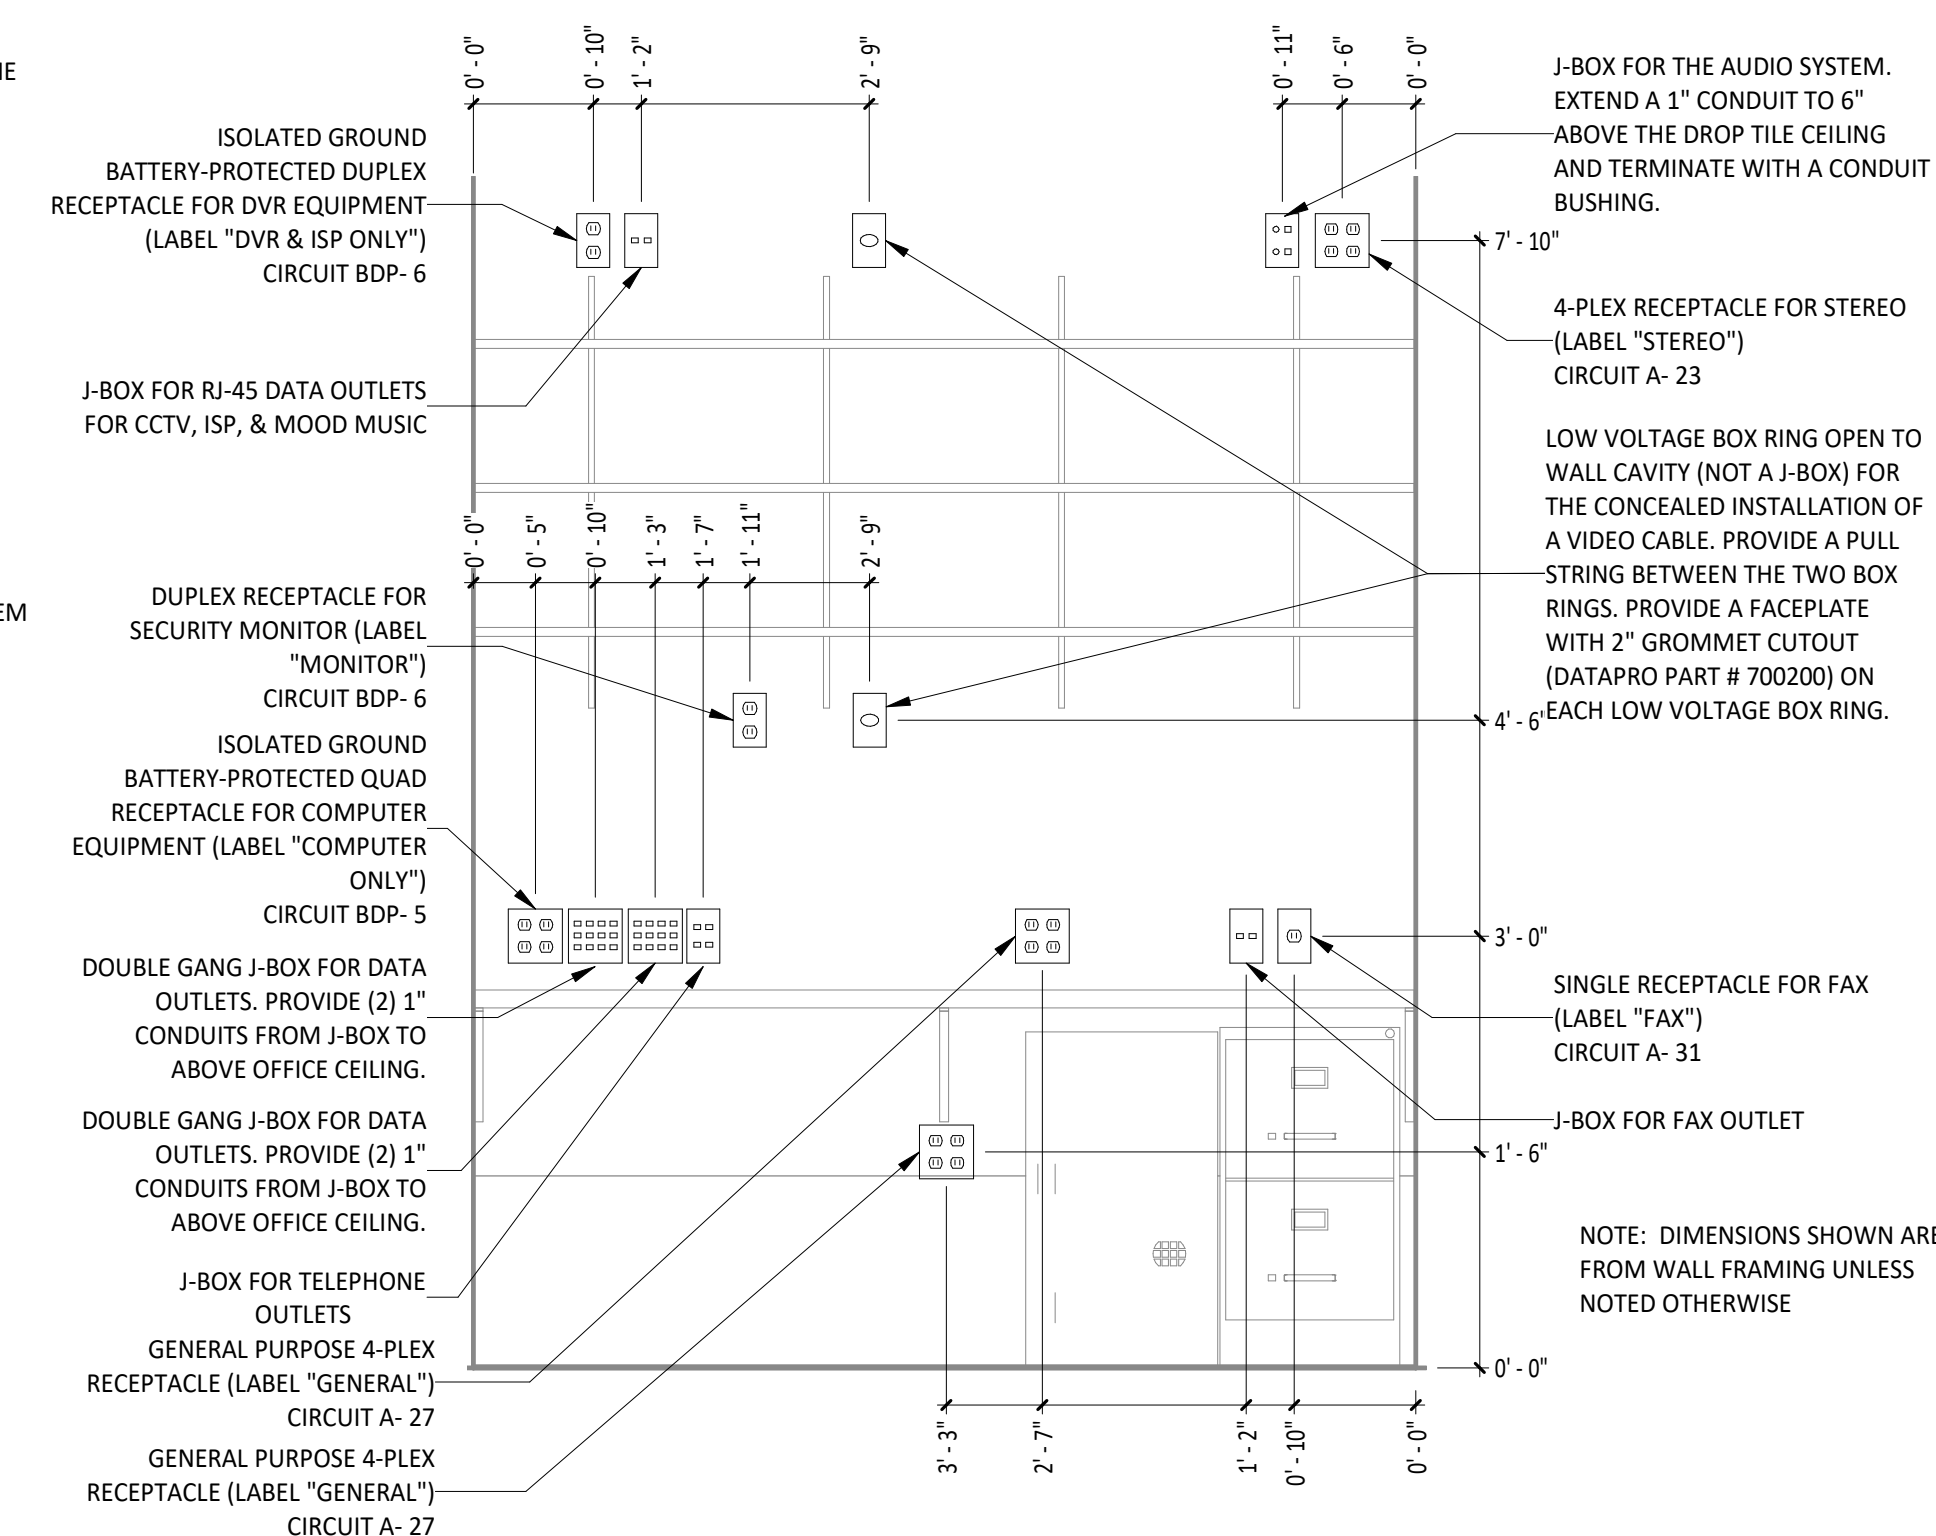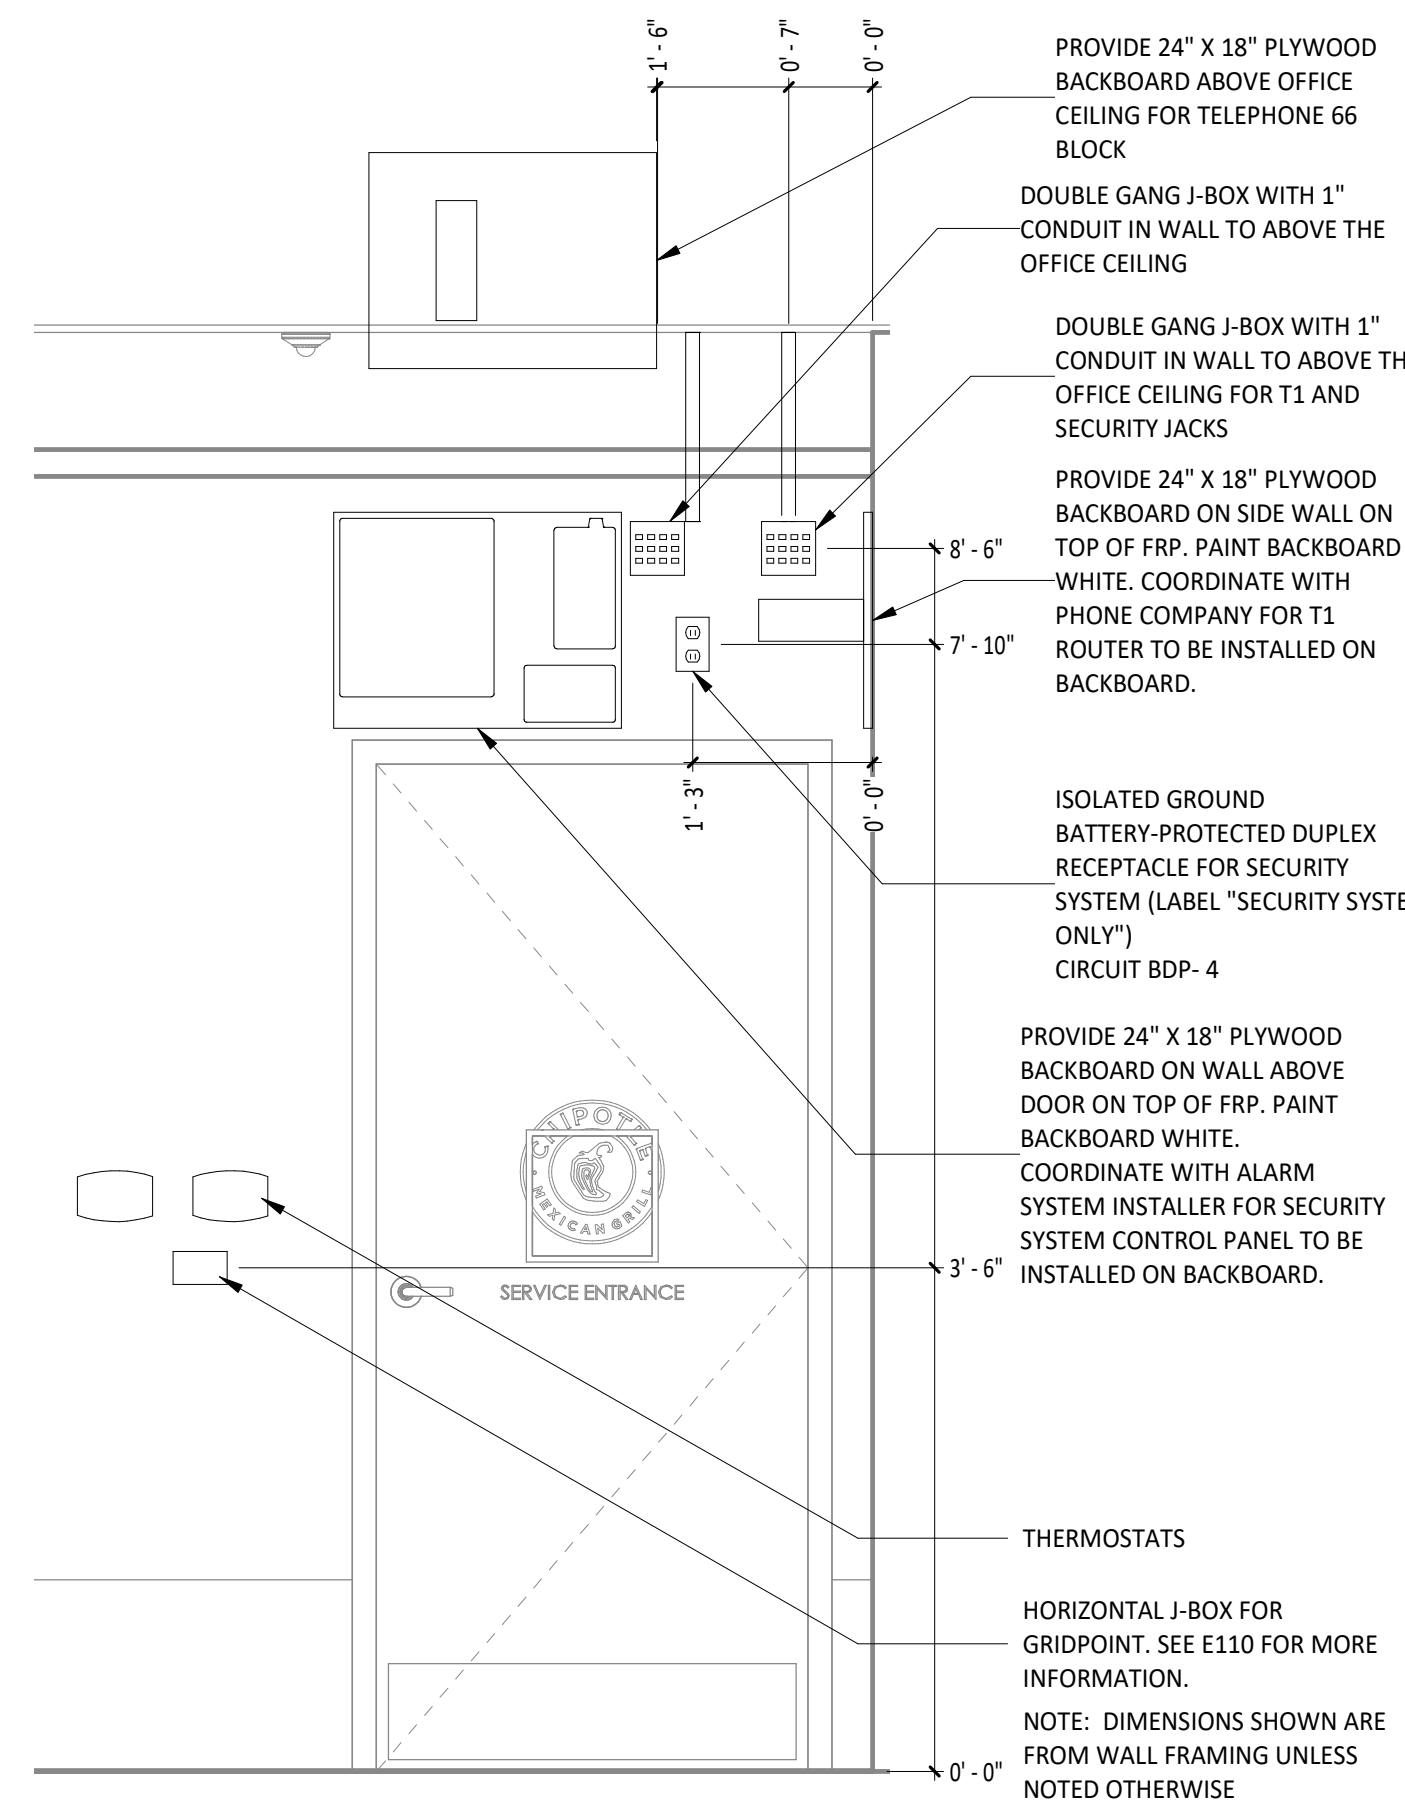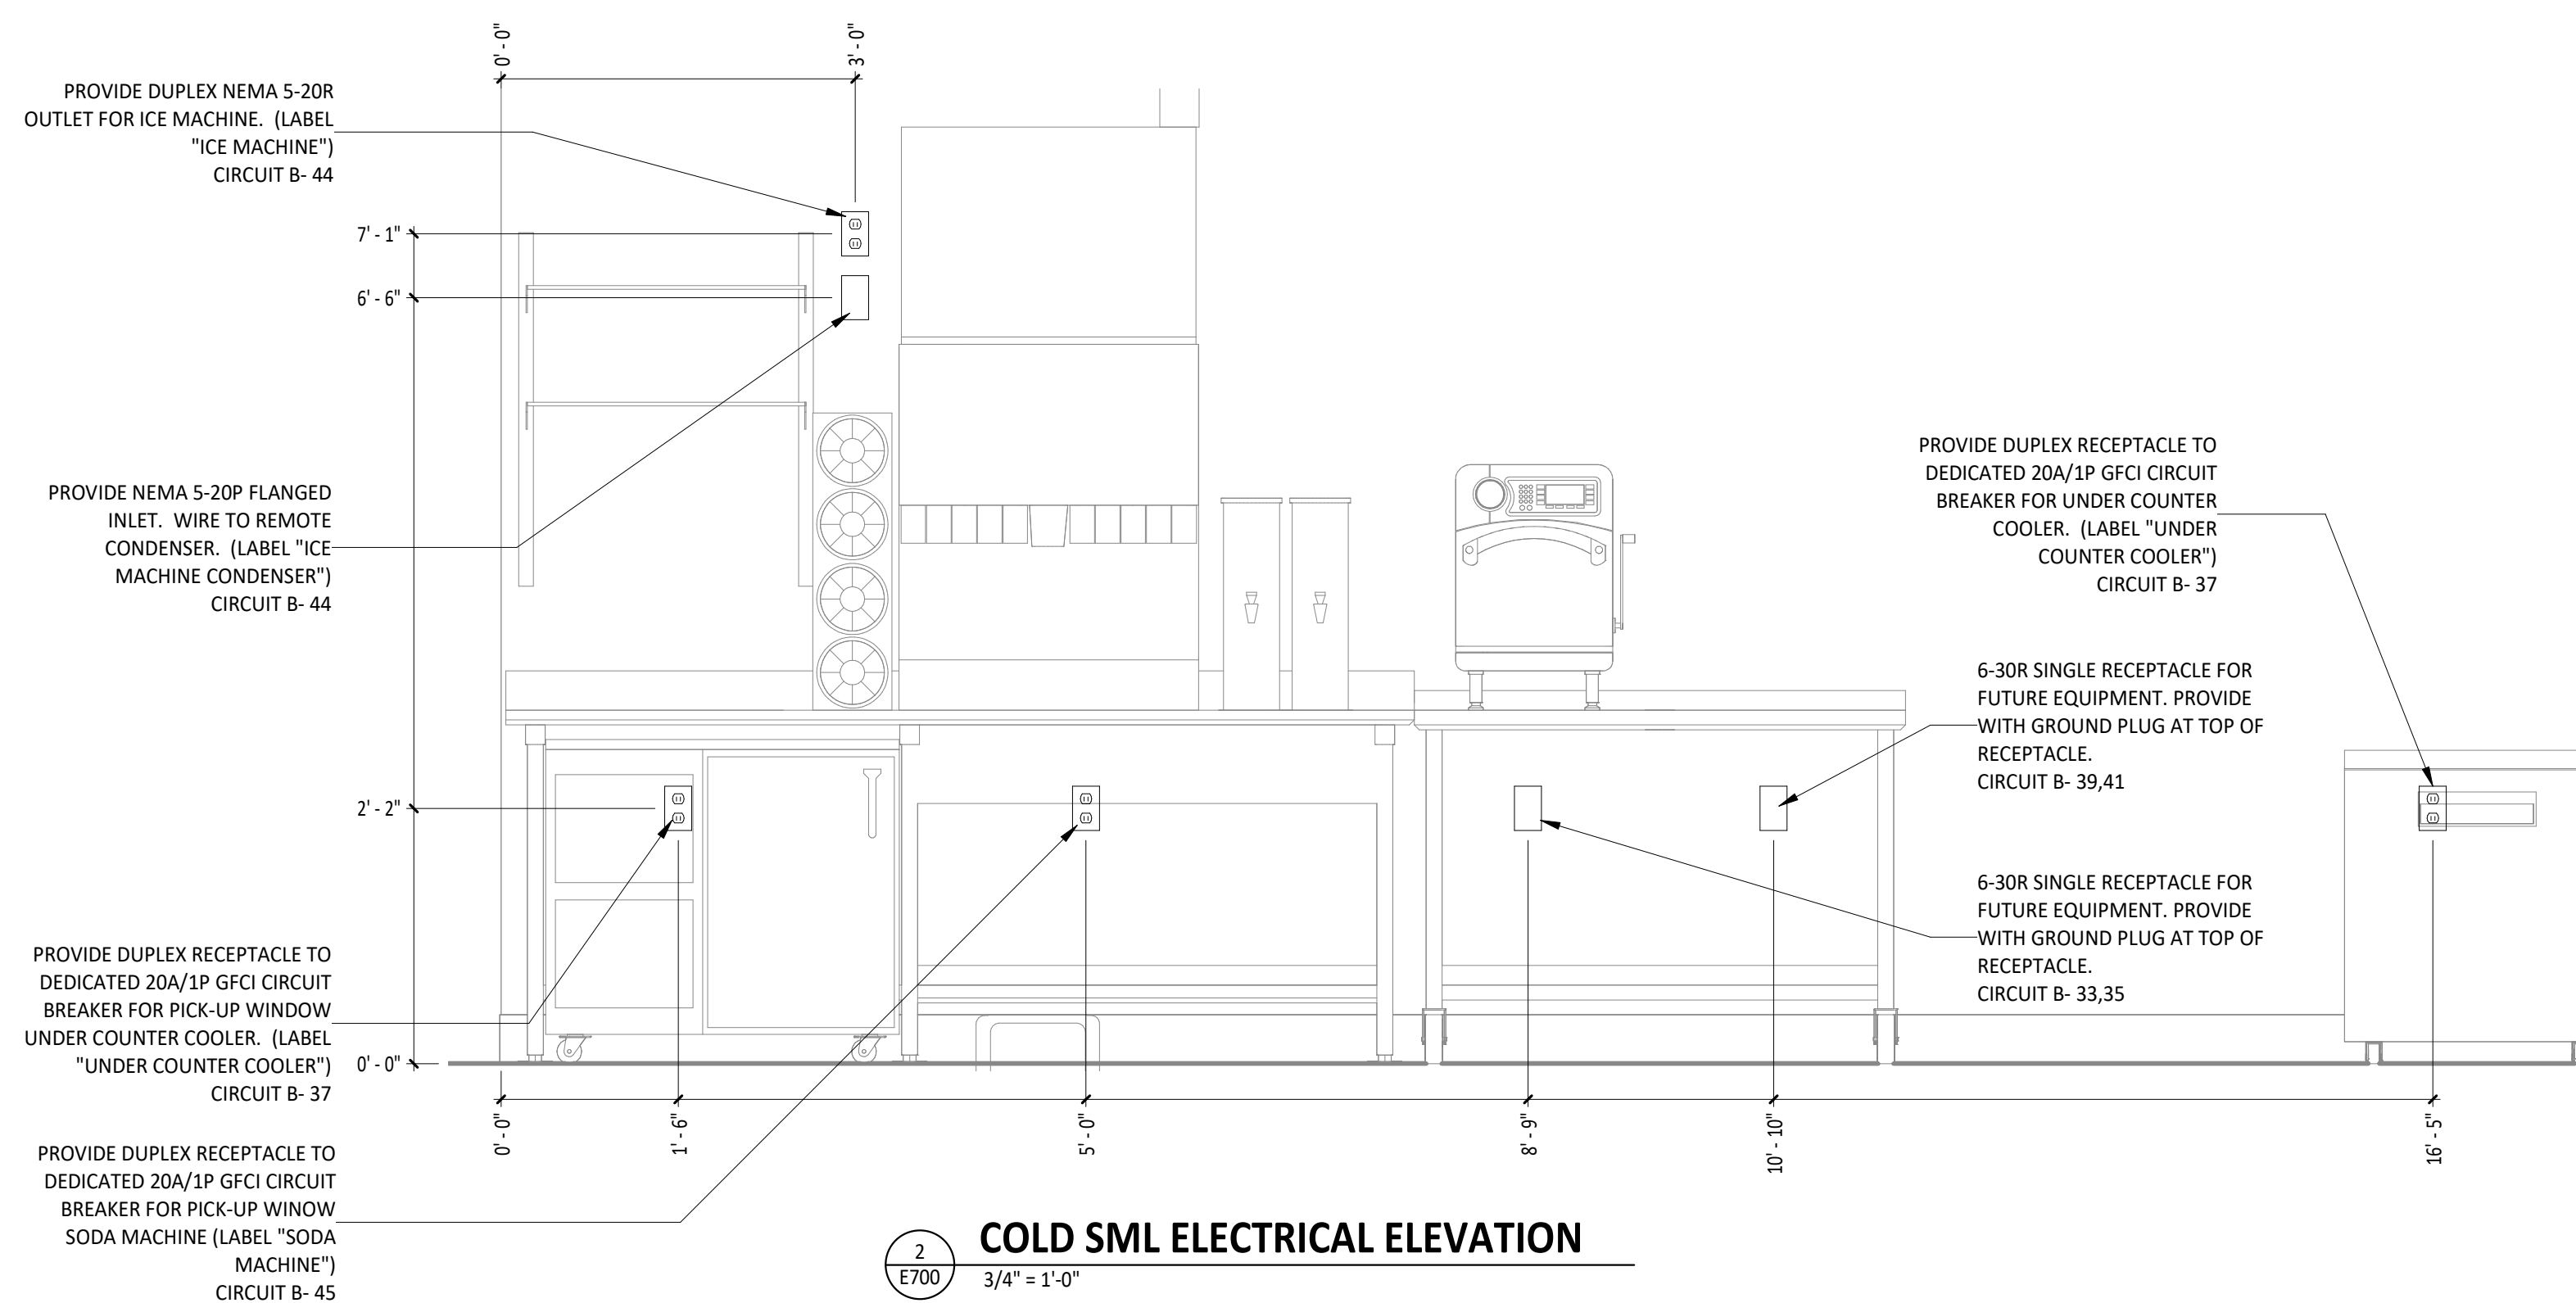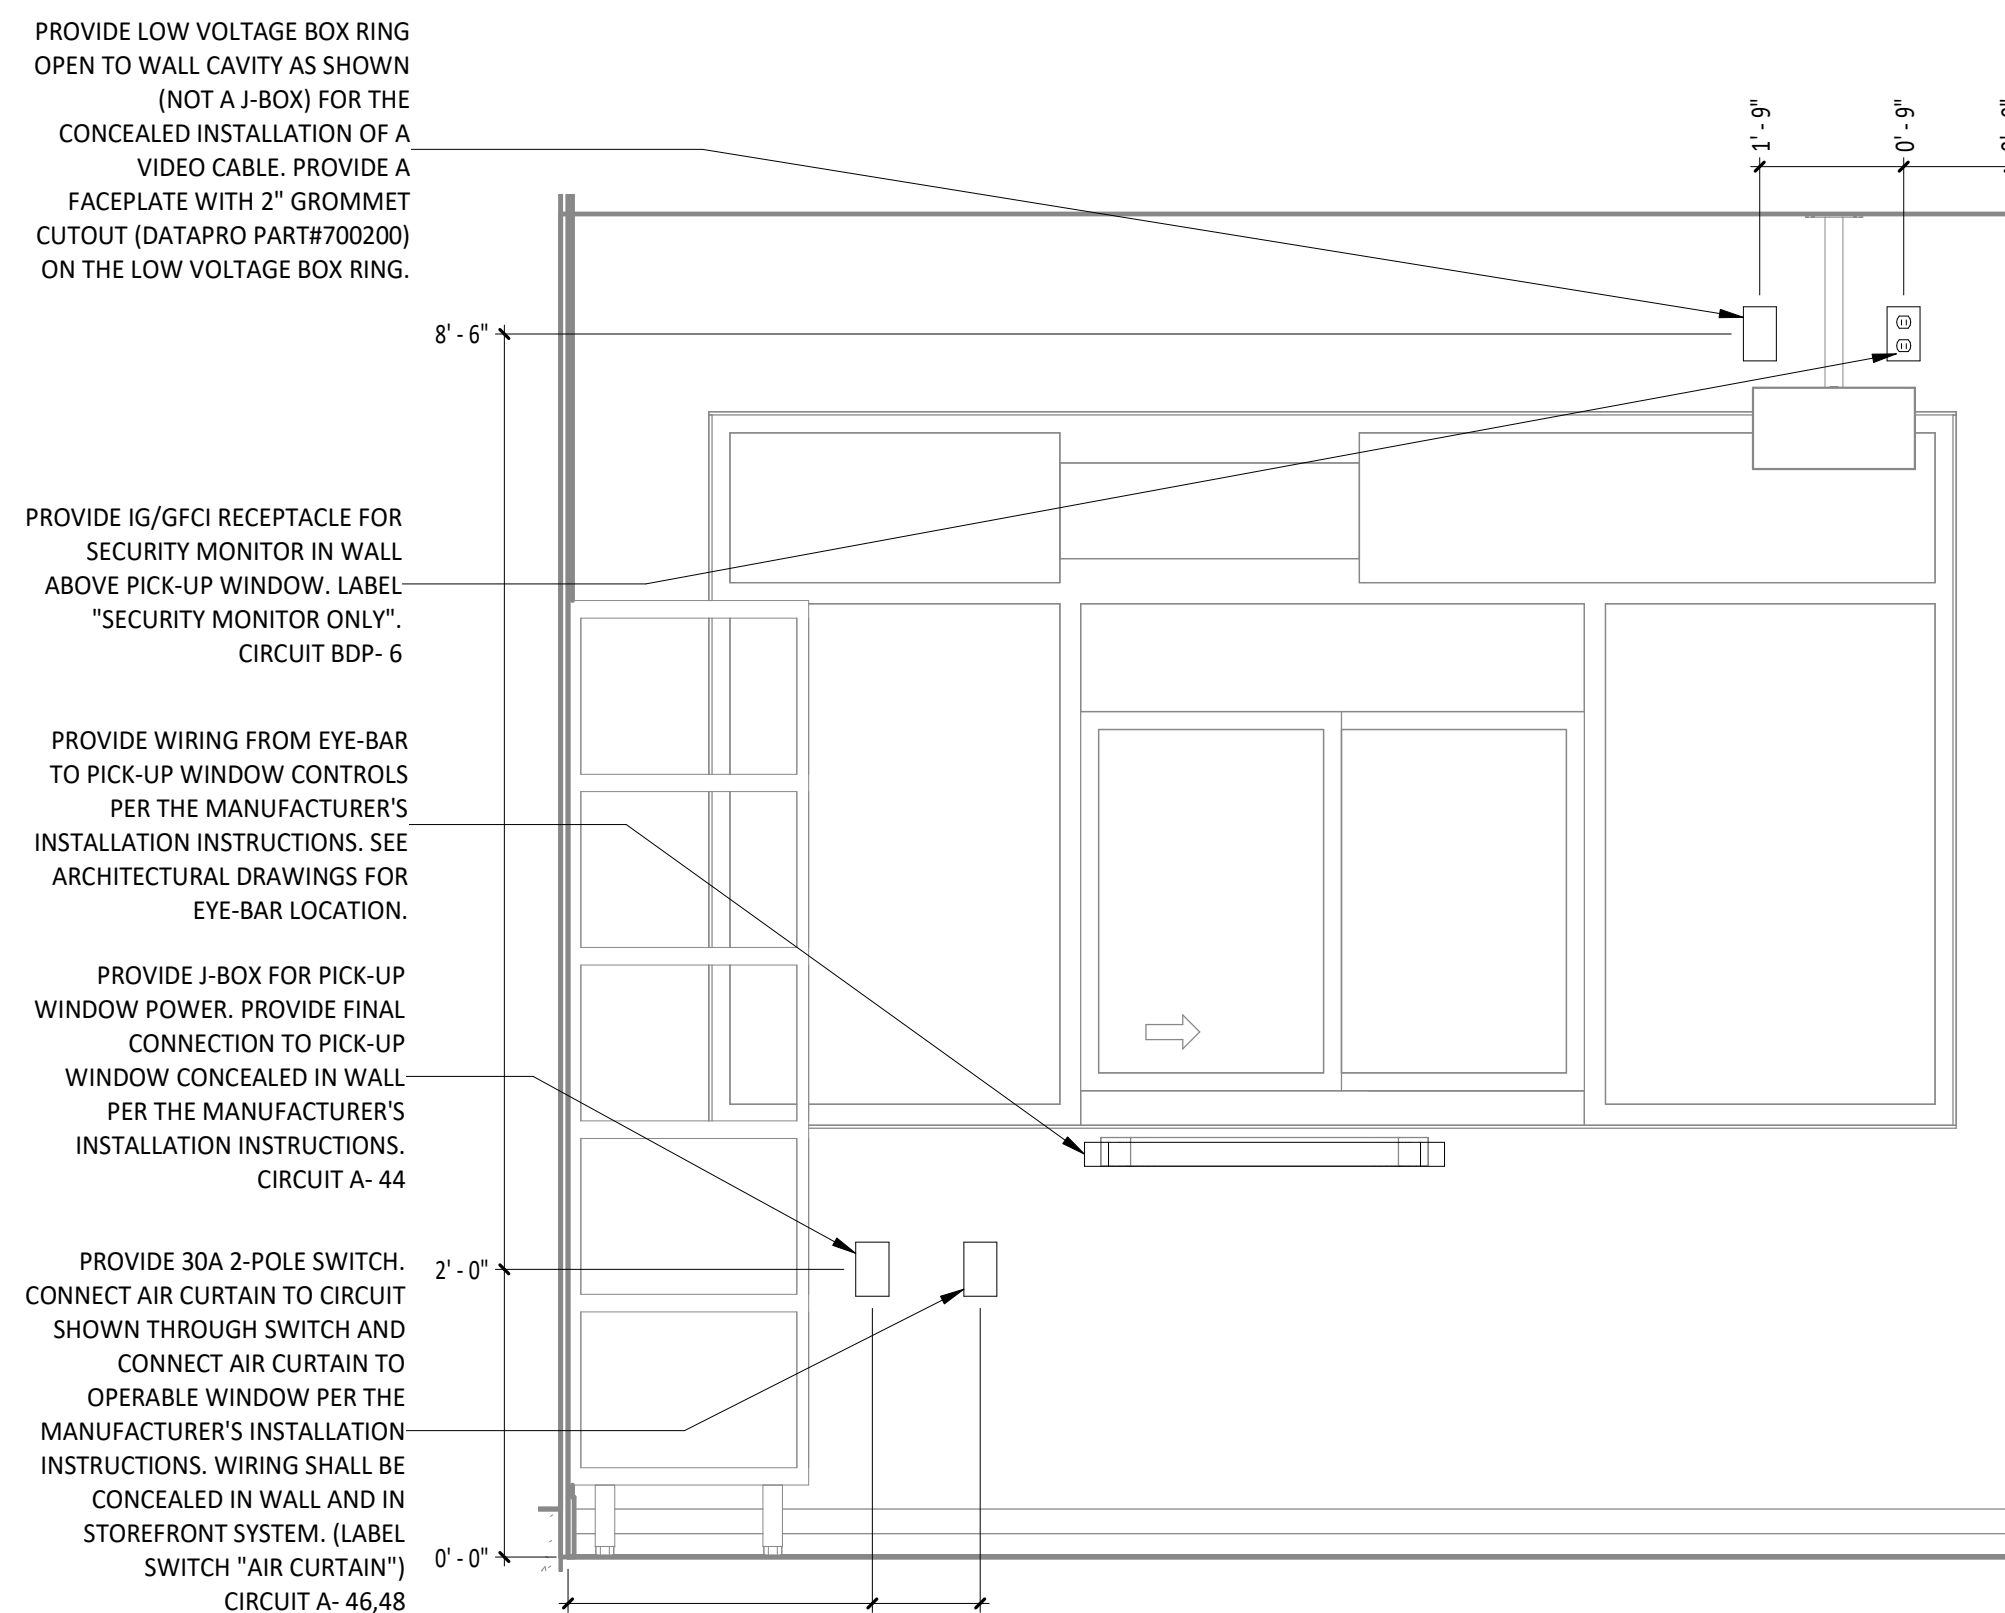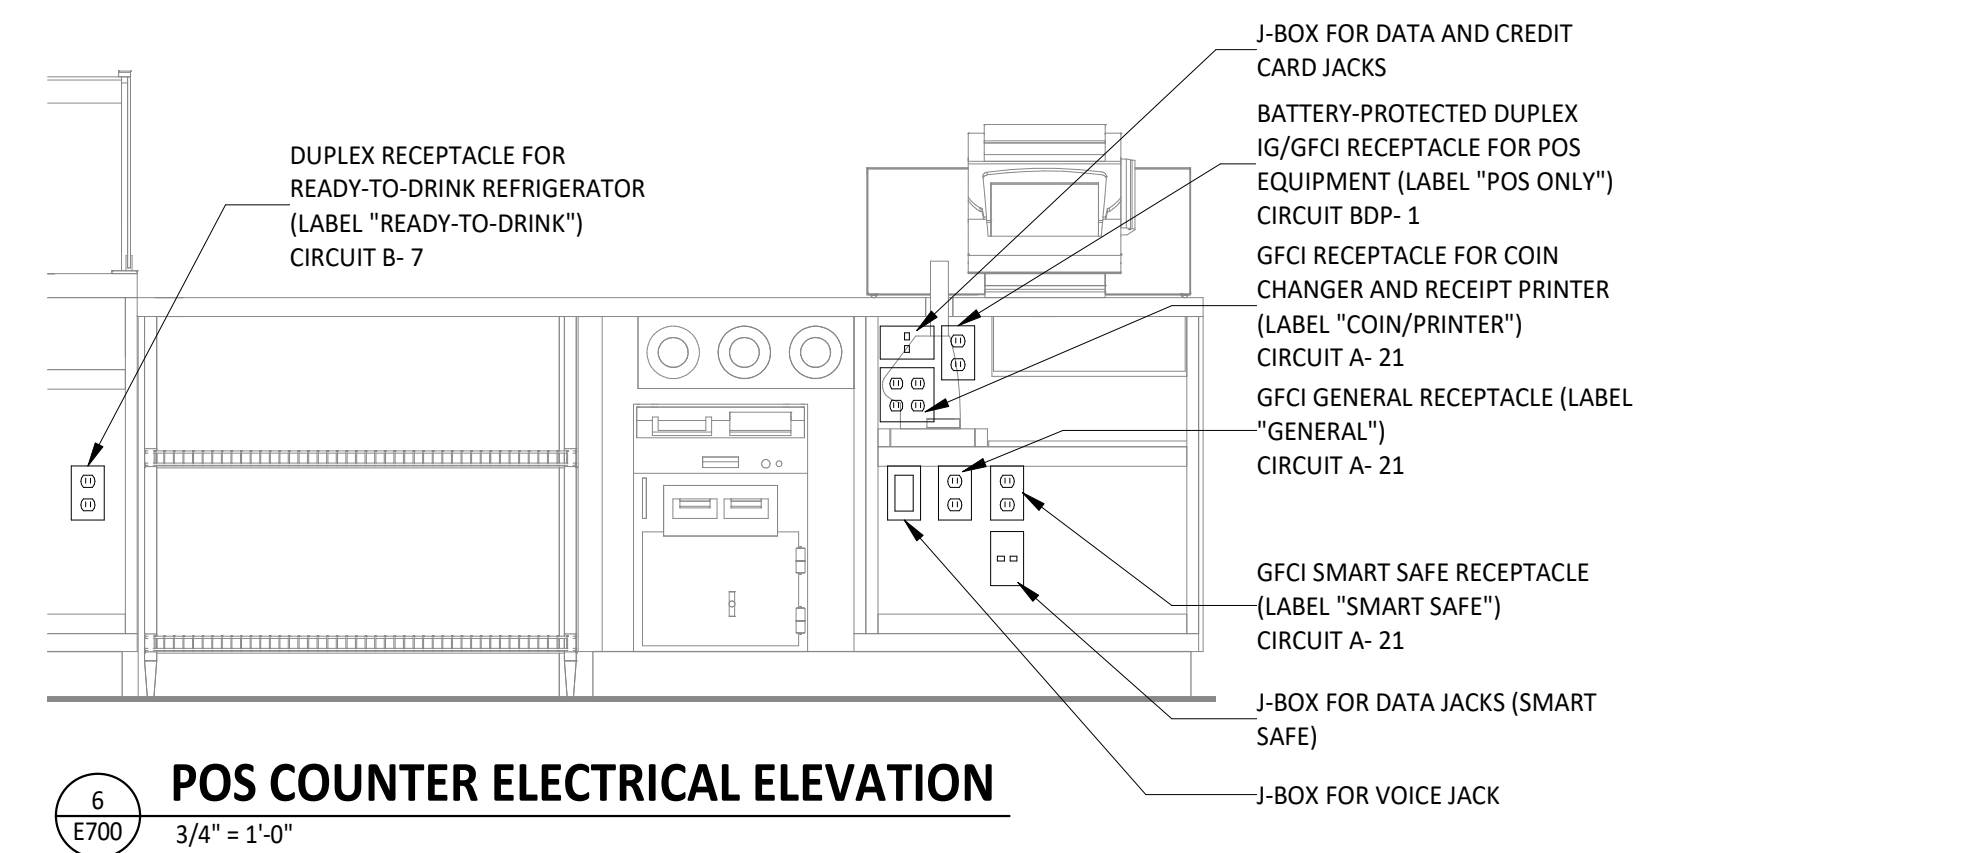

Consultant:



4635 Trueman Blvd. Suite 250
Hilliard, Ohio 43026
Phone: (614) 751-9610
Fax: (614) 552-5240
Contact: Cliff Kigar
(614) 328-2033
ckigar@nationalengineering.com

FOR CONSTRUCTION

COPYRIGHT 2024
THIS DRAWING IS AN INSTRUMENT OF SERVICE
AND AS SUCH REMAINS THE PROPERTY OF
CHIPOTLE MEXICAN GRILL, INC.. PERMISSION FOR
USE OF THIS DOCUMENT IS LIMITED AND CAN BE
EXTENDED ONLY BY WRITTEN AGREEMENT WITH
CHIPOTLE MEXICAN GRILL, INC..



CHIPOTLE MEXICAN GRILL, INC.
PO BOX 182566
COLUMBUS, OH 43218-2566
TELEPHONE: (614) 318-2400
INTERNET: WWW.CHIPOTLE.COM

STORE NO.: 4870
WALNUT HILLS, OH
1202 E. MCMILLAN
CINCINNATI, OH 45206

Issue Record:	
<u>11/03/2023</u>	PERMIT SET
<u>05/08/2024</u>	CONSTRUCTION SET

Revisions:		PLAN REVIEW COMMENTS
2	4/25/24	

Drawn: _____ Checked: _____
CJL JEI


Project No.
2301004

Contents:

ELECTRICAL INTERIOR ELEVATIONS

E700

Consultant:

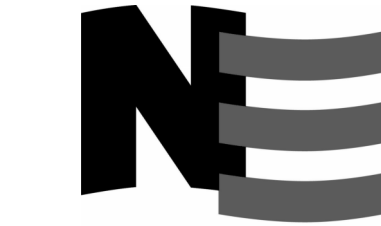

4635 Trueman Blvd, Suite 250
Hilliard, Ohio 43026
Phone: (614) 751-9610
Fax: (614) 552-5240
Contact: Cliff Kigar
(614) 328-2033
ckigar@nationalengineering.com

FOR CONSTRUCTION

COPYRIGHT 2024
THIS DRAWING IS AN INSTRUMENT OF SERVICE
AND AS SUCH REMAINS THE PROPERTY OF
CHIPOTLE MEXICAN GRILL, INC.. PERMISSION FOR
USE OF THIS DOCUMENT IS LIMITED AND CAN BE
EXTENDED ONLY BY WRITTEN AGREEMENT WITH
CHIPOTLE MEXICAN GRILL, INC..



CHIPOTLE MEXICAN GRILL, INC.
PO BOX 182566
COLUMBUS, OH 43218-2566
TELEPHONE: (614) 318-2400
INTERNET: WWW.CHIPOTLE.COM

STORE NO.: 4870
WALNUT HILLS, OH
1202 E. MCMILLAN
CINCINNATI, OH 45206

Issue Record:	
11/03/2023	PERMIT SET
05/08/2024	CONSTRUCTION SET

Revisions:	
2	4/25/24 PLAN REVIEW COMMENTS


Drawn:	Checked:
CJK	JEJ

Project No.
2301004


Contents:

ELECTRICAL INTERIOR
ELEVATIONS

E705

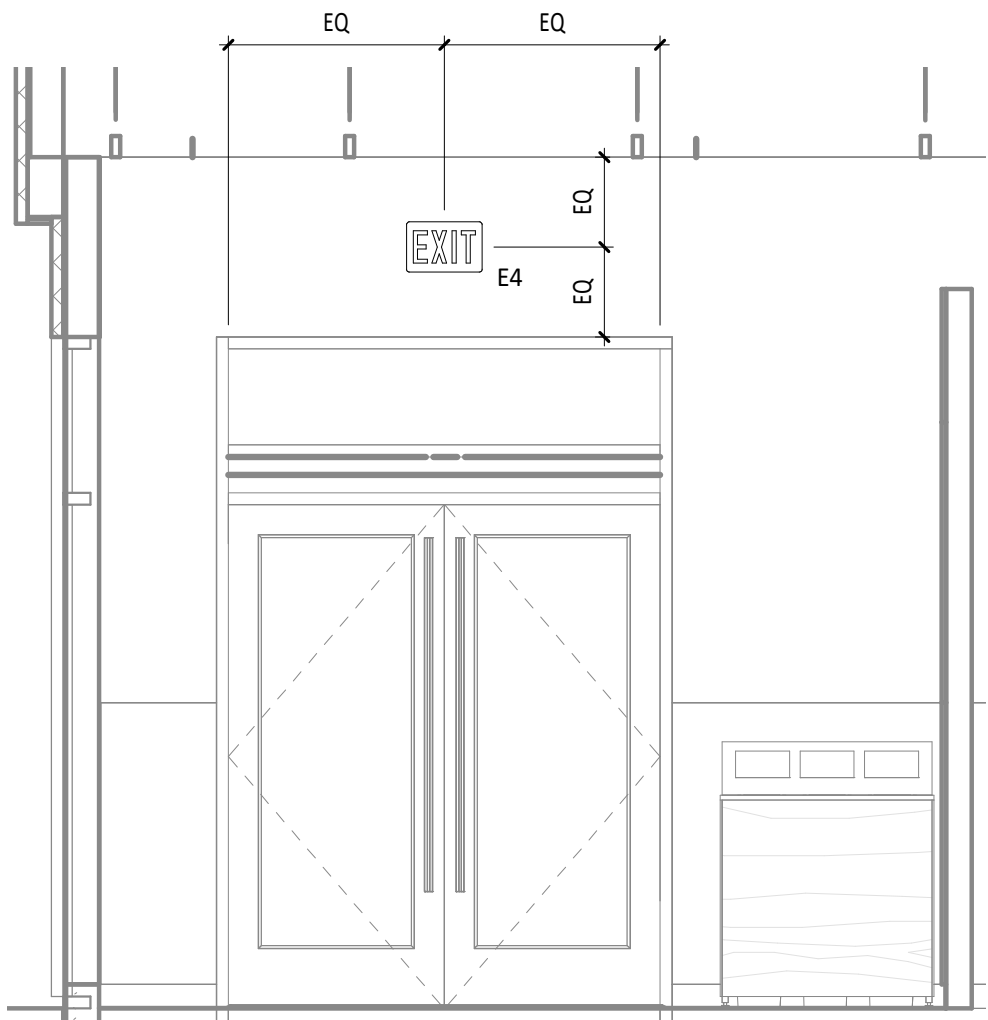

2
E705
DINING ROOM ELECTRICAL ELEVATION
3/8" = 1'-0"

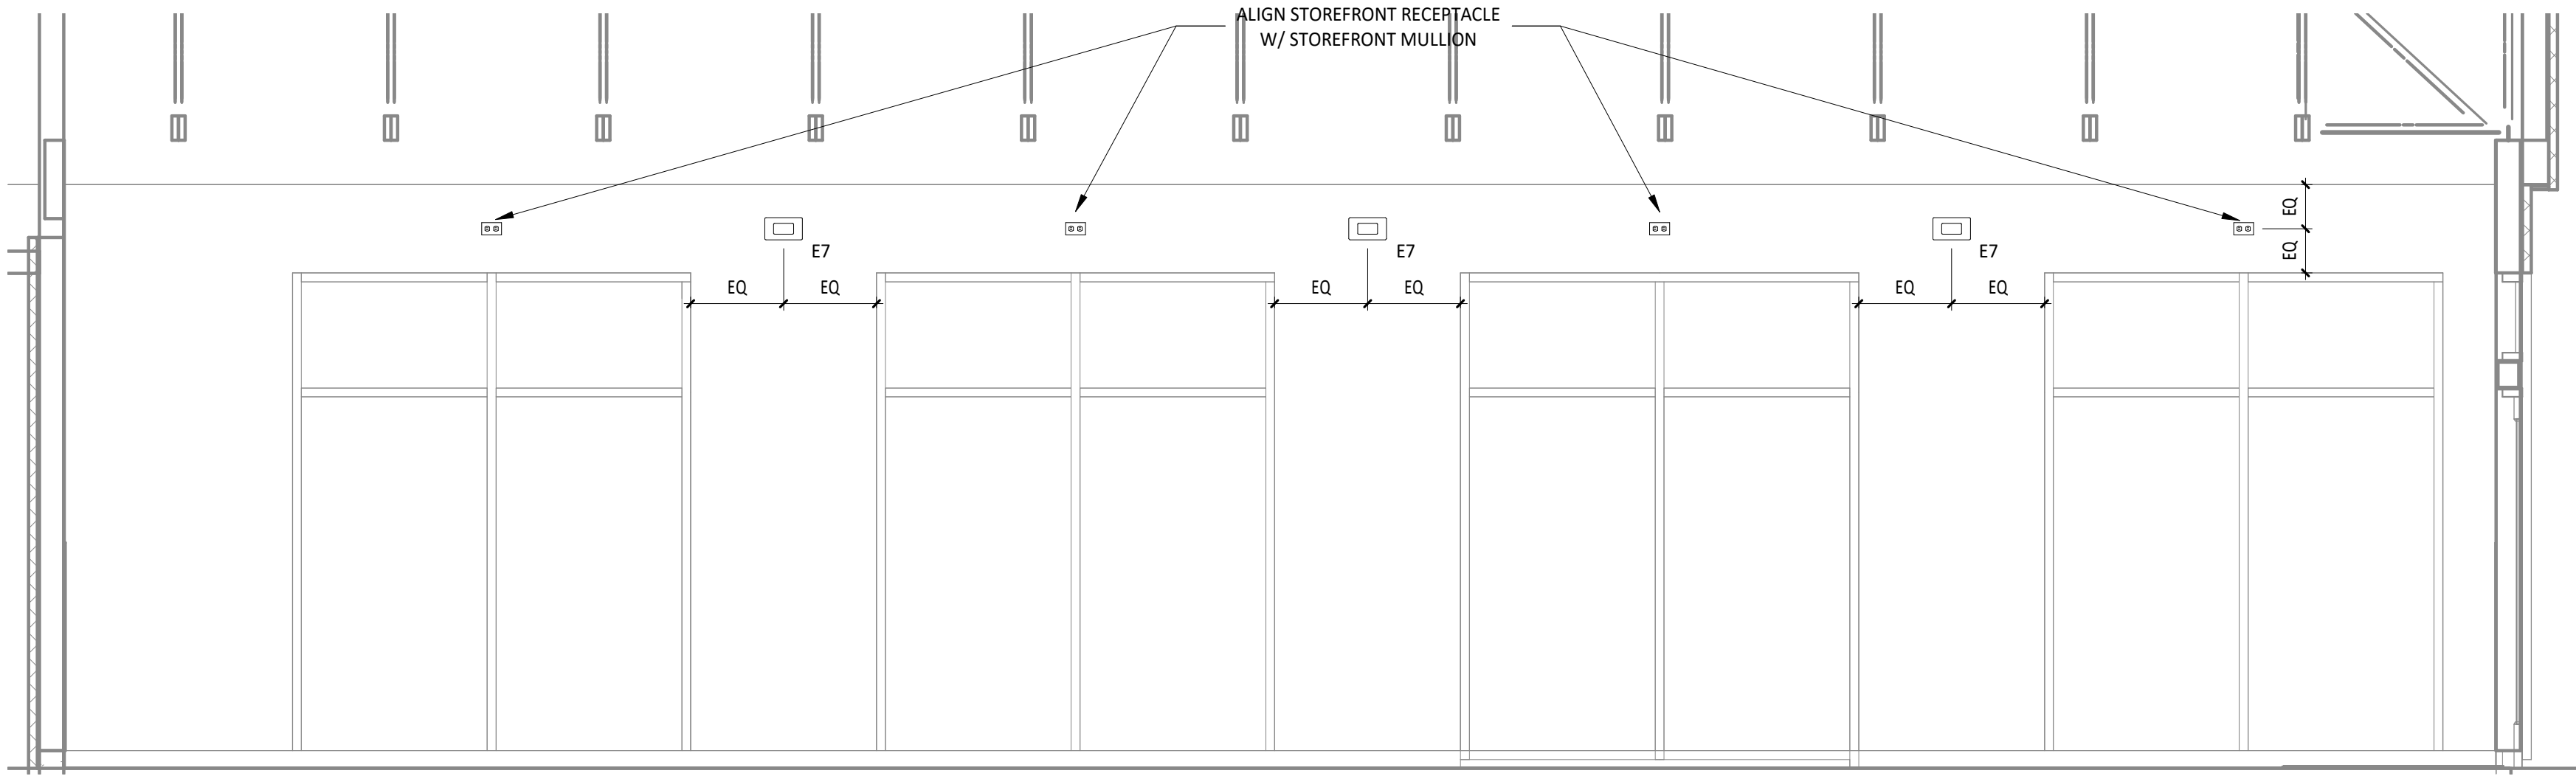

1
E705
DINING ROOM ELECTRICAL ELEVATION
3/8" = 1'-0"

GRIDPOINT DIAGRAM NOTES

1. INSTALL GRIDPOINT THERMOSTATS FURNISHED BY TEMS FOR RTU-1 AND RTU- 2. PROVIDE THERMOSTAT WIRING FROM EACH THERMOSTAT TO THE CORRESPONDING ROOFTOP UNIT.
2. PROVIDE CATSE CABLE FROM RTU-1 THERMOSTAT TO J-BOX #2 ABOVE ELECTRICAL PANELS (LEAVE 16" OF CABLE COILED UP INSIDE OF J-BOX #2 AND 16" BEHIND WALL OF THERMOSTAT FOR FINAL CONNECTION TO THE EMS SYSTEM BY THE TEMS) AND LABEL BOTH ENDS OF CABLE "TSTATS".
3. PROVIDE CATSE CABLE(S) BETWEEN THERMOSTATS (LEAVE 16" OF CABLE BEHIND WALL OF EACH THERMOSTAT FOR FINAL CONNECTION BY THE TEMS) AND LABEL BOTH ENDS OF CABLE "TSTAT JUMPER". SEE GRIDPOINT INSTALLATION INSTRUCTIONS FOR TERMINATION INSTRUCTIONS.
4. INSTALL GRIDPOINT ZONE SENSOR MODULES FURNISHED BY TEMS AS SHOWN ON HVAC FLOOR PLAN. PROVIDE 18G-24G SHIELDED TWISTED PAIR FROM ZSM TO CORRESPONDING THERMOSTAT T1 TERMINALS. SEE GRIDPOINT INSTALLATION INSTRUCTIONS FOR TERMINATION INSTRUCTIONS.
5. INSTALL GRIDPOINT SUPPLY PROBE FURNISHED BY TEMS AS SHOWN ON HVAC FLOOR PLAN. PROVIDE 18G-24G SHIELDED TWISTED PAIR FROM SUPPLY PROBE TO CORRESPONDING THERMOSTAT T2 TERMINALS. SEE GRIDPOINT INSTALLATION INSTRUCTIONS FOR TERMINATION INSTRUCTIONS.
6. PROVIDE 3/4" LIQUIDTIGHT CONDUIT FROM DISH SANITIZING MACHINE TO LOW-VOLTAGE JUNCTION BOX OR TRIM RING FLUSH MOUNTED TO WALL. PROVIDE CONTINUOUS (NOT SPLICED) CATSE CABLE FROM DISH SANITIZING MACHINE TO OFFICE (ABOVE LAY-IN CEILING) WITH 54" SLACK WITHIN THE DISH MACHINE AND 10' SLACK ABOVE THE LAY-IN CEILING. PROVIDE RJ-12 PLUG ON CABLE AT DISH MACHINE END WITH BLUE WIRE CONNECTED TO PIN 3 AND BLUE/WHITE WIRE CONNECTED TO PIN 4. LABEL CABLE ON BOTH ENDS WITH "DISHWASHER".
7. PROVIDE CATS CABLE FROM J-BOX #2 TO OFFICE ABOVE LAY-IN CEILING AND LABEL "RS-485 COMMS" ON BOTH ENDS OF THE CABLE. LEAVE 10' OF SLACK CABLE ABOVE OFFICE CEILING AND 16" OF SLACK CABLE INSIDE OF J-BOX #2.
8. PROVIDE CABLE (18-24AWG SHIELDED TWISTED PAIR) FROM J-BOX #2 TO OFFICE ABOVE LAY-IN CEILING AND LABEL "EMS POWER" ON BOTH ENDS OF THE CABLE. LEAVE 10' OF SLACK CABLE ABOVE OFFICE CEILING AND 16" OF SLACK CABLE INSIDE OF J-BOX #2.
9. PROVIDE SURFACE MOUNT 10" X 10" X 4" NEMA 1 ENCLOSURES ABOVE PANELBOARDS AND 6" BELOW CEILING.
10. PROVIDE 3/4" CONDUIT WITH INSULATING BUSHING ON END CONCEALED IN WALL FROM J-BOX #2 TO 6" ABOVE LAY-IN CEILING.
11. PROVIDE 3/4" CONDUIT(S) FROM J-BOX #1 TO J-BOX #2.
12. PROVIDE EMPTY 1" CONDUIT(S) FROM PANELBOARD(S) TO J-BOX #1 FOR FUTURE CT WIRING BY TEMS.
13. FIRST PANELBOARD FED FROM ELECTRICAL SERVICE. PROVIDE WITH (1) 20A/3-POLE CIRCUIT BREAKER (FOR GRIDPOINT 3 PHASE METER). IF PANELBOARD HAS 120V CIRCUITS AVAILABLE THEN ALSO PROVIDE (1) 20/1-POLE CIRCUIT BREAKER (FOR GRIDPOINT TRANSFORMER).
14. IF SPACE HAS MULTIPLE ELECTRICAL SERVICES THEN PROVIDE A "J-BOX #1" AND ASSOCIATED BREAKERS, CONDUITS, AND CONDUCTORS ON THE FIRST PANELBOARD FED FROM EACH ELECTRICAL SERVICE.
15. FOR EACH ELECTRICAL SERVICE PROVIDE (1) SET OF [(4) #12, #12 G.] FROM 3-POLE GRIDPOINT CIRCUIT BREAKER AND, IF THE PANELBOARD HAS 120V CIRCUITS AVAILABLE, (1) SET OF [(2) #12, #12 G.] FROM 1-POLE GRIDPOINT CIRCUIT BREAKER IN 3/4" CONDUIT CONCEALED IN WALL TO J-BOX #1. TERMINATE IN J-BOX #1 WITH 16" SLACK FOR FINAL CONNECTION BY TEMS.
16. IF THE PANELBOARD DOES NOT HAVE 120V CIRCUITS AVAILABLE PROVIDE A 1-POLE 120V 20A CIRCUIT BREAKER IN A PANEL WITH A 120V CIRCUIT AVAILABLE. PROVIDE (1) SET OF [(2) #12, #12 G.] FROM THE GRIDPOINT CIRCUIT BREAKER IN 3/4" CONDUIT CONCEALED IN WALL TO J-BOX #1. TERMINATE IN J-BOX #1 WITH 16" SLACK FOR FINAL CONNECTION BY TEMS.
17. GRIDPOINT CONTROLLER PROVIDED BY TEMS
18. PROVIDE HORIZONTAL SINGLE-GANG J-BOX BELOW FUTURE GRIDPOINT CONTROLLER LOCATION AS SHOWN. PROVIDE 3/4" CONDUIT WITH PULL STRING AND INSULATING BUSHING FROM J-BOX TO 6" ABOVE OFFICE LAY-IN CEILING.

NOTE:

ARRANGEMENT SHOWN IS DIAGRAMMATIC - SEE PLANS FOR ACTUAL DEVICE LOCATIONS.

WARE WASHING

OFFICE

PANELBOARD AREA

GRIDPOINT WIRING DIAGRAM

SEQUENCE OF OPERATIONS

- A. EMERGENCY LIGHT FIXTURES, EXIT SIGNS, LOCALLY-SWITCHED FIXTURES, AND FIXTURES DESIGNATED AS NIGHT LIGHTS ARE NOT CONTROLLED THROUGH THE RELAY PANEL.
- B. ALL TIMES NOTED SHALL BE LOCAL TIME AND SHALL AUTOMATICALLY ADJUST FOR DAYLIGHT SAVINGS TIME, IF APPLICABLE.
- C. ALL KITCHEN LIGHTING CIRCUITS AND RESTROOM EXHAUST FAN CIRCUIT (R1, R2, R7) SHALL BE ENERGIZED AT FULL POWER FROM 7:00AM UNTIL MIDNIGHT AND SHALL BE DE-ENERGIZED AT OTHER TIMES.
- D. ALL DINING ROOM LIGHTING CIRCUITS (R4, R5, R6) SHALL BE ENERGIZED FROM 10:00AM UNTIL MIDNIGHT AND SHALL BE DE-ENERGIZED AT OTHER TIMES.
- E. EXTERIOR LIGHTING/SIGNAGE RELAY (R8) SHALL BE ENERGIZED FROM ONE HOUR BEFORE SUNSET UNTIL ONE HOUR AFTER CLOSING AND SHALL BE DE-ENERGIZED AT OTHER TIMES.
- F. OVERRIDES: WHEN ONE OF THE OVERRIDE BUTTONS IS PRESSED THE SYSTEM WILL GO INTO OVERRIDE MODE FOR THE DURATION NOTED BELOW OR UNTIL THE NEXT SCHEDULED EVENT. FOLLOWING THIS PERIOD THE RELAYS WILL RETURN TO THE CURRENT SCHEDULED CONDITION. DURING THIS OVERRIDE TIME THE CORRESPONDING LAMP WILL ILLUMINATE ON THE OVERRIDE BUTTON.
- G. INTERIOR (CHANNEL 1): WHEN THE INTERIOR OVERRIDE ON OR OFF BUTTON IS PRESSED (CHANNEL 1) RELAYS R1, R2, R4, R5, R6, AND R7 WILL BE ENERGIZED OR DE-ENERGIZED FOR A DURATION OF ONE (1) HOUR.
- H. KITCHEN DIMMING (CHANNEL 2): WHEN THE KITCHEN NORMAL/DIM OVERRIDE ON OR OFF BUTTON IS PRESSED (CHANNEL 2) RELAY R2 WILL BE ENERGIZED OR DE-ENERGIZED FOR A DURATION OF ONE (1) HOUR.
- I. DINING DIMMING (CHANNEL 3): WHEN THE DINING NORMAL/DIM OVERRIDE ON OR OFF BUTTON IS PRESSED (CHANNEL 3) RELAYS R5 AND R6 WILL BE ENERGIZED OR DE-ENERGIZED FOR A DURATION OF ONE (1) HOUR.
- J. EXTERIOR (CHANNEL 4): WHEN THE EXTERIOR OVERRIDE ON OR OFF BUTTON IS PRESSED (CHANNEL 4) RELAY R8 WILL BE ENERGIZED OR DE-ENERGIZED FOR A DURATION OF ONE (1) HOUR.
- K. VERIFY THAT TIME, TIME ZONE, AND LONGITUDE/LATITUDE ARE SET CORRECTLY ON LCP. VERIFY WITH STORE OPERATIONS THAT THE ON/OFF TIMES ARE COMPATIBLE WITH THE STORE OPERATING HOURS PRIOR TO TURNOVER.

CO2 ALARM OPTIONS

CO2 DETECTOR	X
CO2 REMOTE DISPLAY UNIT	X
REMOTE STROBE	
RELAY	

INSTALL STROBE WITH WIRING TO CO2 DETECTOR SEU OR RDU (FURNISHED BY CO2AS) (IF REQUIRED). PROVIDE 3/4" CONDUIT IN WALL FROM STROBE LOCATION TO ABOVE CEILING TO CONCEAL WIRING.

CO2 TANK (BULK TANK OR CANISTERS)
PROVIDE GFCI RECEPTACLE J-BOX ADJACENT TO THE CO2 TANK/BAG-IN-BOX AS SHOWN ON THE ELECTRICAL POWER PLAN.

INSTALL CO2METER RAD-0102-06 CARBON DIOXIDE STORAGE SAFETY ALARM SEU (FURNISHED BY CO2AS) ADJACENT TO THE CO2 TANK/BAG-IN-BOX AS SHOWN.

CONNECT THE SYSTEM POWER TO THE RECEPTACLE AS SHOWN. INSTALL CABLE TO MINIMIZE SLACK AT CO2 DETECTOR. SECURE CABLE TO WALL.

AT SEU J-BOX, INSTALL MOUNTING PLATE TO TOP SCREW HOLE OF J-BOX WITH THE MOUNTING PLATE EXTENDING UP ABOVE THE TOP OF THE J-BOX IN THE ORIENTATION SHOWN.

CO2 ALARM DETAIL

N.T.S.

ELECTRICAL CONNECTIONS SHALL BE ON THE OPPOSITE SIDE OF THE DISH MACHINE FROM THE 3-COMP SINK. IF THIS IS ON THE LEFT SIDE OF THE DISH MACHINE THEN LIQUID TIGHT CONDUIT SHALL BE ROUTED BEHIND THE DISH MACHINE TO THE ELECTRICAL CONNECTIONS ON THE RIGHT SIDE OF THE DISH MACHINE..

POWER FOR DISH SANITIZING MACHINE SHALL BE FED FROM A DEDICATED 2-POLE LOCKABLE CIRCUIT BREAKER. PROVIDE FINAL CONNECTION FROM J-BOX IN WALL TO DISH SANITIZING MACHINE USING LIQUIDTIGHT FLEXIBLE METAL CONDUIT.

PROVIDE CONDUITS AND WIRING FOR GRIDPOINT CONNECTION TO DSM AS SHOWN IN DETAIL 8/E710.

DISH SANITIZING MACHINE ELECTRICAL DETAIL

N.T.S.

NOTE: EQUIPMENT SHOWN IS TYPICAL. SEE PLAN FOR ACTUAL EQUIPMENT AND LOCATIONS.

TERMINATE CONDUITS ABOVE CEILING WITH CONDUIT BUSHINGS. TYPICAL.

PROVIDE CONTINUOUS CATS CABLE WITH RJ45 CONNECTOR ON EACH END FROM THE SEU TO THE RDU AND FROM EACH STROBE TO A SEU/RDU (IF REQUIRED). CATS CABLES SHALL NOT BE SPLICED.

PROVIDE 1" CONDUITS CONCEALED IN WALL FROM SEU AND RDU J-BOX TO ABOVE THE LAY-IN CEILING. ALL CO2 MONITOR CABLING (OTHER THAN THE SEU POWER CABLE) SHALL BE CONCEALED WITHIN CONDUITS.

INSTALL CO2 ALARM RDU (FURNISHED BY CO2AS) AT ENTRANCE TO THE CO2 STORAGE AREA AS SHOWN.

CO2 REMOTE DISPLAY UNIT/J-BOX
48" AFF

PROVIDE JUNCTION BOX AT ENTRANCE TO THE CO2 STORAGE AREA AS SHOWN ON THE ELECTRICAL POWER PLAN.

AT RDU J-BOX, INSTALL MOUNTING PLATE TO TOP SCREW HOLE OF J-BOX WITH THE MOUNTING PLATE EXTENDING DOWN BELOW THE TOP OF THE J-BOX IN THE ORIENTATION SHOWN.

RDU J-BOX

LEGEND

PREWIRED CONDUCTOR

FIELD-WIRED CONDUCTOR

NOTE

REVIEW BDP PANEL INSTALLATION INSTRUCTIONS PRIOR TO INSTALLATION.

BYPASS DISTRIBUTION PANEL WIRING DIAGRAM

N.T.S.

PROVIDE CONTACTOR IN ACCESSIBLE LOCATION ABOVE LAY-IN CEILING FOR CONTROL OF EXTERIOR LIGHTING AND SIGNAGE

PROVIDE LOW-VOLTAGE WIRING TO FIXTURES CONTROLLED BY 0-10V DIMMING (IF APPLICABLE)

PROVIDE POWER WIRING TO RELAY-CONTROLLED FIXTURES AND DEVICES.

INSTALL ACUITY nLIGHT ARP LIGHTING CONTROL PANEL. SEE SHEET E100 FOR LOCATION.

INSTALL ACUITY nLIGHT 4-CHANNEL SWITCH WITH WHITE BUTTONS, SS PLATE, AND BUTTON ENGRAVING. SEE SHEET E100 FOR LOCATION. ENGRAVING AS FOLLOWS:
CHANNEL 1 ON/OFF: "INT ON"/ "INT OFF"
CHANNEL 2 ON/OFF: "KITCH NORM"/ "KITCH DIM"
CHANNEL 3 ON/OFF: "DINE NORM"/ "DINE DIM"
CHANNEL 4 ON/OFF: "EXT ON"/ "EXT OFF"

INTERIOR LIGHTING CONTROL DIAGRAM

N.T.S.

PEDESTAL OUTLET DETAIL

N.T.S.

3/4" FLEXIBLE METALLIC LIQUIDTIGHT CONDUIT TO J-BOX INTEGRAL TO ISLAND PREP TABLE. HOLD LIQUIDTIGHT CONDUIT OFF FLOOR.
90° STEEL LIQUIDTIGHT CONDUIT ELBOW (RACO 3423-8 OR EQUAL)
3/4" RIGID METAL CONDUIT COUPLING
SEAL BETWEEN RIGID METAL CONDUIT AND CURB
SEE ARCHITECTURAL PLANS FOR CURB DETAILS
3/4" PVC RIGID NONMETALLIC CONDUIT (OR OTHER APPROVED UNDERGROUND CONDUIT MATERIAL) TO PANELBOARD
3/4" RIGID METAL CONDUIT ELBOW

EXISTING POLE-MOUNTED TRANSFORMER WITH 120/208V, 3Ø SECONDARY

EXISTING (4) 500 KCMIL CU, #1/0 G. IN 4" C.

EXISTING 400/400/3 EXISTING 120/208 V 400A METER

N.T.S.

MAIN DISTRIBUTION DIAGRAM

N.T.S.

Consultant:



4635 Trueman Blvd. Suite 250
Hilliard, Ohio 43026
Phone: (614) 751-9610
Fax: (614) 552-5240
Contact: Cliff Kigar
(614) 328-2033
ckigar@nationalengineering.com

FOR CONSTRUCTION

COPYRIGHT 2024
THIS DRAWING IS AN INSTRUMENT OF SERVICE AND AS SUCH REMAINS THE PROPERTY OF CHIPOTLE MEXICAN GRILL, INC.. PERMISSION FOR USE OF THIS DOCUMENT IS LIMITED AND CAN BE EXTENDED ONLY BY WRITTEN AGREEMENT WITH CHIPOTLE MEXICAN GRILL, INC..



CHIPOTLE MEXICAN GRILL, INC.
PO BOX 182566
COLUMBUS, OH 43218-2566
TELEPHONE: (614) 318-2400
INTERNET: WWW.CHIPOTLE.COM

STORE NO.: 4870

WALNUT HILLS, OH
1202 E. MCMILLAN
CINCINNATI, OH 45206

Issue Record:
11/03/2023 PERMIT SET
05/08/2024 CONSTRUCTION SET

Revisions:
2 4/25/24 PLAN REVIEW COMMENTS

Drawn: CJK

Checked: JEJ

Project No.

2301004

Contents:

ELECTRICAL DETAILS

E710