



PROJECT GENERAL NOTES	
A.	IN ADDITION TO THE GENERAL NOTES LISTED HEREIN, THE LATEST EDITION OF AIA DOCUMENT A201 GENERAL CONDITIONS OF THE CONTRACT FOR CONSTRUCTION SHALL APPLY.
B.	WORK SHALL BE IN ACCORDANCE WITH FEDERAL, STATE AND LOCAL CODES, ORDINANCES, LAWS AND REQUIREMENTS.
C.	WORK, WHEN COMPLETED, SHALL CONFORM TO THE AMERICANS WITH DISABILITIES ACT AND LOCAL ACCESSIBILITY REQUIREMENTS.
D.	THE CONSTRUCTION DOCUMENTS ARE COMPLEMENTARY, AND WHAT IS REQUIRED BY ONE SHALL BE AS BINDING AS IF REQUIRED BY ALL. COORDINATE PORTIONS OF WORK AS DESCRIBED IN THE CONSTRUCTION DOCUMENTS.
E.	THE CONSTRUCTION DOCUMENTS, AS DEFINED BY THE DRAWING AND SPECIFICATION INDEX, ARE NECESSARY TO DEFINE THE TOTAL PROJECT. PARTIAL PLANS OR SPECIFICATIONS SHOULD NOT BE ISSUED BY ANY PARTIES FOR BIDDING OR CONSTRUCTION.
F.	IT IS THE INTENT OF THE CONSTRUCTION DOCUMENTS TO DESCRIBE A COMPLETE AND FINISHED PROJECT, OTHER THAN ITEMS NOTED "NIC" (NOT IN CONTRACT), ERRORS, OMISSIONS AND INCONSISTENCIES THAT MAY OCCUR BETWEEN THE CONSTRUCTION DOCUMENTS AND/OR EXISTING CONDITIONS SHALL BE BROUGHT IMMEDIATELY TO THE ATTENTION OF THE ARCHITECT IN WRITING AND WRITTEN INSTRUCTIONS SHALL BE OBTAINED PRIOR TO PROCEEDING WITH THE WORK. THE GENERAL CONTRACTOR SHALL BE HELD RESPONSIBLE FOR THE RESULTS OF ANY ERRORS, DISCREPANCIES AND/OR OMISSIONS WHICH THE GENERAL CONTRACTOR FAILED TO NOTIFY THE ARCHITECT PRIOR TO CONSTRUCTION AND/OR FABRICATION OF THE WORK.
G.	GENERAL CONTRACTOR SHALL INCLUDE AND PROVIDE ALL LABOR, MATERIALS, EQUIPMENT, TRANSPORTATION AND PAY EXPENSES INCURRED IN THE PROPER COMPLETION OF WORK UNLESS SPECIFICALLY NOTED TO BE THE WORK OF OTHERS. GENERAL CONTRACTOR SHALL PERFORM WORK NECESSARY FOR PRODUCTION OF A COMPLETE, HABITABLE PROJECT AS DEFINED BY THE SCOPE OF WORK.
H.	DO NOT SCALE DRAWINGS. BIDDER (CONTRACTOR) SHALL VERIFY CONDITIONS AND DIMENSIONS AT JOB SITE PRIOR TO START OF CONSTRUCTION. IF DISCREPANCIES ARE FOUND, WHETHER BUILT OR NOT, THE ARCHITECT SHALL BE NOTIFIED FOR CLARIFICATION BEFORE COMMENCING WORK.
I.	THE STATED DIMENSIONS SHALL TAKE PRECEDENCE OVER GRAPHIC. THE ARCHITECT SHALL BE NOTIFIED OF ANY DISCREPANCIES.
J.	NOTE THAT ERRORS IN THE TRANSMISSION OR REPRODUCTION OF THESE CONSTRUCTION DOCUMENTS COULD RESULT IN ALTERATIONS OF LINE TYPES, THICKNESSES, TONES, COLORS, HATCH PATTERNS AND SCALE. WILKUS ARCHITECTS IS NOT RESPONSIBLE FOR ANY CLAIMS, DAMAGES OR EXPENSES ARISING FROM THE UNAUTHORIZED USE OF THE INFORMATION CONTAINED WITHIN.
K.	IF THE CONSTRUCTION DOCUMENTS APPEAR TO BE UNCLEAR, AMBIGUOUS OR CONTRADICTORY, AND IN THE EVENT THAT THE CONTRACTOR, OR SUBCONTRACTOR, DETERMINES CLARIFICATION OR INTERPRETATION BY THE ARCHITECT IS REQUIRED, THE GENERAL CONTRACTOR SHALL SUBMIT A REQUEST FOR INFORMATION IN WRITING TO THE ARCHITECT PRIOR TO START OF THE WORK.
a.	REQUESTS FOR INFORMATION MAY ONLY BE MADE BY THE GENERAL CONTRACTOR. THE GENERAL CONTRACTOR SHALL CLEARLY AND CONCISELY SET FORTH THE ISSUE FOR WHICH CLARIFICATION IS SOUGHT AND WHY A RESPONSE IS NEEDED FROM THE ARCHITECT AND/OR CONSULTANTS. IN THE REQUEST FOR INFORMATION, THE CONTRACTOR SHALL SET FORTH AN UNDERSTANDING OF THE REQUIREMENT, ALONG WITH A REASON WHY SUCH AN UNDERSTANDING WAS REACHED.
b.	THE ARCHITECT WILL REVIEW THE REQUEST FOR INFORMATION TO DETERMINE IF IT IS WITHIN THE MEANING OF THIS TERM. IF THE ARCHITECT DETERMINES THAT IT IS NOT A REQUEST FOR INFORMATION, IT WILL BE RETURNED TO THE CONTRACTOR UNREVIEWED AS TO CONTENT OR FOR RE-SUBMITTAL IN THE PROPER FORM AND MANNER.
c.	RESPONSES TO REQUESTS FOR INFORMATION SHALL BE ISSUED UPON RECEIPT, BUT NO LATER THAN FIVE WORKING DAYS OF RECEIPT. UNLESS IT IS DETERMINED THAT A LONGER PERIOD OF TIME IS NEEDED IN ORDER TO PROVIDE ADEQUATE RESPONSE, IF A LONGER PERIOD OF TIME IS NECESSARY, THE ARCHITECT WILL, WITHIN FIVE WORKING DAYS OF THE RECEIPT OF THE REQUEST FOR INFORMATION, NOTIFY THE GENERAL CONTRACTOR OF THE ANTICIPATED RESPONSE TIME.
d.	IF THE REQUEST FOR INFORMATION IS SUBMITTED WITH FIVE WORKING DAYS OR LESS FLOAT ON THE PROJECT SCHEDULE, THE CONTRACTOR SHALL NOT BE ENTITLED TO ANY TIME EXTENSION DUE TO THE TIME REQUIRED TO REVIEW AND RESPOND, PROVIDED A RESPONSE IS GIVEN WITHIN THE FIVE WORKING DAYS AS SET FORTH ABOVE.
e.	RESPONSES FROM THE ARCHITECT ARE NOT INTENDED TO CHANGE ANY OF THE REQUIREMENTS OF THE CONSTRUCTION DOCUMENTS. IN THE EVENT THAT THE CONTRACTOR BELIEVES A RESPONSE WILL CAUSE A CHANGE TO THE REQUIREMENTS OF THE CONSTRUCTION DOCUMENTS, THE CONTRACTOR SHALL IMMEDIATELY GIVE WRITTEN NOTICE TO THE ARCHITECT AND CLIENT STATING THAT THEY CONSIDER THE RESPONSE TO BE A CHANGE ORDER. FAILURE TO GIVE SUCH WRITTEN NOTICE IMMEDIATELY SHALL WAIVE THE CONTRACTORS RIGHT TO SEEK ADDITIONAL TIME AND/OR COST.
L.	ANY DIMENSIONS, DETAILS, NOTES AND/OR SYMBOLS THAT APPLY TO ONE UNIT, APPLY TO ALL UNITS IN LIKE SITUATIONS, UNLESS NOTED OTHERWISE.
M.	FOR THE PURPOSE OF THESE DOCUMENTS, "INSTALL" SHALL MEAN TO PROVIDE FASTENERS, MISCELLANEOUS HARDWARE, BLOCKING, ELECTRICAL CONNECTIONS, PLUMBING CONNECTIONS AND ANY OTHER ITEMS REQUIRED FOR A COMPLETE AND OPERATIONAL INSTALLATION, UNLESS NOTED OTHERWISE.
N.	FOR THE PURPOSE OF THESE DOCUMENTS, "BY GC" WILL REFER TO ITEMS PROVIDED AND INSTALLED BY THE GENERAL CONTRACTOR, THEIR SUBCONTRACTORS AND/OR AGENTS. THE TERM "BY CLIENT" WILL REFER TO ITEMS PROVIDED BY THE CLIENT AND INSTALLED BY THE GENERAL CONTRACTOR.
O.	PRODUCTS THAT HAVE BEEN USED IN PREPARING THESE DOCUMENTS, ARE TO ESTABLISH MINIMUM QUALITIES. PROPOSED SUBSTITUTIONS MUST MEET THESE QUALITIES, OR BETTER, TO BE CONSIDERED ACCEPTABLE. THE BURDEN OF PROOF OF EQUALITY RESTS WITH THE GENERAL CONTRACTOR. ADEQUATE SUPPORTING DOCUMENTATION MUST ACCOMPANY SUBSTITUTION REQUEST SUBMITTALS, WHICH MUST BE SUBMITTED TO THE ARCHITECT FOR APPROVAL PRIOR TO BIDDING.
P.	GENERAL CONTRACTOR SHALL VISIT THE PROJECT SITE PRIOR TO SUBMISSION OF BID AND BEGINNING OF ANY WORK TO EXAMINE AND COMPARE THE DRAWINGS AND SPECIFICATIONS TO THE EXISTING CONDITIONS AND BE KNOWLEDGEABLE OF WORK TO BE PERFORMED. NOTIFY ARCHITECT IMMEDIATELY OF ANY DISCREPANCIES.
Q.	NOTIFY ALL PARTIES IF HAZARDOUS MATERIALS ARE SUSPECTED OR FOUND TO BE PRESENT.
R.	NOTIFY ARCHITECT IMMEDIATELY OF EXISTING CONDITIONS THAT ARE EXPOSED DURING CONSTRUCTION THAT MAY IMPACT ANY PROPOSED NEW WORK.
S.	DO NOT ATTEMPT REMOVAL OF ANY STRUCTURE OR ELEMENT SUSPECTED OF BEING STRUCTURAL IN NATURE. STRUCTURAL MODIFICATIONS TO THE BUILDING OR STRUCTURAL SYSTEMS (OF ANY TYPE) REQUIRE APPROVAL FROM THE BUILDING OWNER AND AN APPROVED STRUCTURAL ENGINEER.
T.	GENERAL CONTRACTOR TO PROVIDE TEMPORARY BARRICADES, WINDOW BLACKOUTS AND DUST CONTROL AS REQUIRED BY CLIENT, LANDLORD OR AUTHORITY HAVING JURISDICTION FOR THE DURATION OF CONSTRUCTION. VEHICULAR ACCESS MUST BE PROVIDED AND MAINTAINED SERVICEABLE THROUGHOUT CONSTRUCTION.
V.	THROUGHOUT THE PROJECT, THE GENERAL CONTRACTOR SHALL CLOSELY SUPERVISE THE WORK OF SUBCONTRACTORS AND SHALL BE SOLELY RESPONSIBLE FOR CONSTRUCTION MEANS, METHODS AND TECHNIQUES, INCLUDING SAFETY PROCEDURES AND FOR COORDINATING/SEQUENCING TRADES.
W.	GENERAL CONTRACTOR SHALL TAKE OUT ANY NECESSARY TRADE-LEVEL PERMITS, INSURANCE, LICENSES, BONDS AND CERTIFICATES AND PAY ALL FEES CONNECTED TO THE WORK DESCRIBED HEREIN.
X.	ALL CONTRACTORS FOR THE WORK ARE REQUIRED TO HAVE INSURANCE OF ALL TYPES AND LIMITS, AS REQUIRED FOR THIS PROJECT.
Y.	REFER TO ENGINEERED CONSTRUCTION DOCUMENTS BY OTHERS FOR ADDITIONAL PERTINENT INFORMATION.
Z.	ABREVIATIONS ARE PER THE UNITED STATES NATIONAL CAD STANDARD - FOUND IN MODULE 5 - TERMS AND ABBREVIATIONS.
AA.	REFER TO INDIVIDUAL DRAWINGS WITHIN THIS SET OF CONSTRUCTION DOCUMENTS FOR ADDITIONAL GENERAL NOTES.
CC.	GENERAL CONTRACTOR IS RESPONSIBLE TO CONTACT (client, landlord, etc) TO VERIFY, COORDINATE AND COMPLY, DURING THE BIDDING PHASE, WITH REQUIREMENTS INCLUDING, BUT NOT LIMITED TO BARRICADES, STAGING, CONSTRUCTION PROCEDURES, USE OF MANDATED SUBCONTRACTORS, DEBRIS REMOVAL, RESTRICTED HOURS OF CONSTRUCTION, SECURITY, UTILITIES, ETC.
DD.	GENERAL CONTRACTOR SHALL FURNISH AND INSTALL ITEMS WHICH ARE OBVIOUS AND NECESSARY TO ENSURE QUALITY WORKMANSHIP AND INSTALLATION, EVEN IF NOT SPECIFICALLY MENTIONED IN THE DRAWINGS, INCLUDING BUT NOT LIMITED TO BLOCKING AND BRACING.
EE.	ANY DEVIATION FROM THESE CONSTRUCTION DOCUMENTS ON THE PART OF THE GENERAL CONTRACTOR, ANY SUBCONTRACTOR, VENDOR AND/OR SUPPLIER, OR USE OF THESE CONSTRUCTION DOCUMENTS FOR USE AT ANY LOCATION OTHER THAN THAT FOR WHICH THEY WERE INTENDED, SHALL RELEASE WILKUS ARCHITECTS, AND ITS SUBSIDIARIES, AND THEIR OFFICERS, DIRECTORS, SHAREHOLDERS, AGENTS, EMPLOYEES, REPRESENTATIVES, SUCCESSORS AND ASSIGNEES, FROM ANY AND ALL LIABILITY INCURRED IN LITIGATION OR OTHERWISE WITH RESPECT TO THE CONSTRUCTION OF THIS PROJECT.
FF.	GENERAL CONTRACTOR IS RESPONSIBLE FOR THEIR WORK AND THAT OF THEIR SUBCONTRACTORS FOR THE LOSSES AND DAMAGES TO EQUIPMENT, EXISTING CONSTRUCTION, TOOLS AND MATERIALS USED IN CONJUNCTION WITH THE WORK, FOR THE ACTS OF THEIR EMPLOYEES AND SUBCONTRACT WORKERS.
GG.	GENERAL CONTRACTOR SHALL ADHERE AND COMPLY WITH FEDERAL, STATE AND LOCAL REGULATIONS REGARDING JOB SAFETY.
HH.	GENERAL CONTRACTOR IS RESPONSIBLE TO CARRY WORKER'S COMPENSATION AS REQUIRED BY LAW AND/OR GOVERNING AUTHORITY.
II.	GENERAL CONTRACTOR IS RESPONSIBLE FOR THE SAFETY AND CARE OF ADJACENT PROPERTIES DURING CONSTRUCTION.
JJ.	GENERAL CONTRACTOR IS RESPONSIBLE FOR MAINTAINING A COMPLETE AS-BUILT SET OF CONSTRUCTION DRAWINGS AT THE JOB SITE AND TURNING THE AS-BUILT DRAWINGS OVER TO THE CLIENT UPON COMPLETION OF THE PROJECT.
KK.	THE APPROVED PLANS (FOR CONSTRUCTION SET) SHALL BE KEPT ON SITE AT ALL TIMES, INCLUDING ALL ADDENDA, SUPPLEMENTAL INSTRUCTIONS, CHANGE ORDERS, COPIES OF APPROVED SUBMITTALS, ETC.
LL.	IF REQUIRED, THE GENERAL CONTRACTOR SHALL PROVIDE SCHEDULING AND/OR COORDINATION WITH THE APPROPRIATE REPRESENTATIVE FOR THE FOLLOWING INSTALLATIONS OR PROCEDURES: a. INSTALLATION OF CONDUIT AND PIPING IN OR BELOW THE FLOOR SLAB. b. CONNECTIONS TO DOMESTIC WATER, SANITARY AND GREASE WASTE, SANITARY VENT AND SMOKE/FIRE ALARMS. c. INSTALLATION OF PRIMARY DUCTWORK, VAV BOXES AND CONTROLS. d. PROGRAMMING OF THE VAV BOX CONTROL AND SENSORS. e. ANY WORK REQUIRED AT THE BUILDING SWITCHGEAR. f. HARDWARE AND SOFTWARE MODIFICATIONS TO COMPLETE THE INTERFACE WITH BASE BUILDING LIFE SAFETY SYSTEM. g. UPON SUBSTANTIAL COMPLETION OF WORK IN THE PREMISES, CLIENT AND THE CONTRACTOR MUST SCHEDULE A FINAL INSPECTION AND PREPARE A PUNCHLIST WHICH ENUMERATES ANY AREAS OF CONSTRUCTION, FIXTURING, LIGHTING OR LAMPING, MERCHANDISING, ETC., THAT ARE NOT IN ACCORDANCE WITH THE CONSTRUCTION DOCUMENTS. ANY STOREFRONT BARRICADE MAY NOT BE REMOVED UNTIL THE INSPECTION AND REQUIRED CORRECTIONS HAVE BEEN COMPLETED. h. LANDLORD'S CONDITIONS IN THE FACILITY TENANT DESIGN GUIDE HANDBOOK SHALL BE A PART OF ANY CONTRACT AND/OR AGREEMENT ENTERED INTO BY THE GENERAL CONTRACTOR. THE GENERAL CONTRACTOR SHALL SCHEDULE A PRE-CONSTRUCTION MEETING WITH THE LANDLORD CONTACT PRIOR TO ANY CONSTRUCTION. i. PROVIDE LANDLORD REQUIRED PROOF OF BUILDERS RISK INSURANCE AND DAMAGE DEPOSIT PRIOR TO BEGINNING OF ANY SELECTIVE DEMOLITION OR NEW CONSTRUCTION.
MM.	GENERAL CONTRACTOR TO VERIFY REQUIREMENTS TO MAINTAIN ROOF WARRANTY. ANY ROOF PATCHING SHALL RETURN THE AFFECTED AREA TO A "LIKE NEW" CONDITION.
NN.	GENERAL CONTRACTOR ASSUMES COMPLETE RESPONSIBILITY WHEN CLIENT FURNISHED ITEMS ARE ACCEPTED AND RECEIVED BY THE GENERAL CONTRACTOR OR THEIR AGENTS.
OO.	PROVIDE PROTECTION FOR EXISTING OR NEWLY INSTALLED SYSTEMS AND FINISHES FOR THE DURATION OF CONSTRUCTION.
PP.	GENERAL CONTRACTOR TO INSTALL DUST PROOFING AND/OR RIGID BARRIERS AS APPROPRIATE TO DEFINE VARIOUS SEGMENTS. BARRIERS TO MAINTAIN EXITING, MECHANICAL, AND FIRE/LIFE SAFETY REQUIREMENTS FOR BUILDING OCCUPANTS.
QQ.	GENERAL CONTRACTOR IS RESPONSIBLE FOR INSPECTION OF PORTIONS OF WORK ALREADY PERFORMED TO DETERMINE THAT SUCH PORTIONS ARE IN PROPER CONDITION TO RECEIVE SUBSEQUENT WORK.
RR.	MOLD AND MOISTURE MITIGATION - GENERAL CONTRACTOR TO COORDINATE AND ENSURE THAT ANY AREA OF THE BUILDING, MATERIAL, OR ASSEMBLY WITHIN THE BUILDING ENVELOPE IS THOROUGHLY CLEANED AND DRY BEFORE BEING COVERED BY CONSTRUCTION. ANY MOLD, MILDEW OR OTHER MOISTURE CONDITION DEVELOPED WITHIN THE SCOPE OF WORK OF THIS CONTRACT (DEMOLITION OR NEW CONSTRUCTION) SHALL BE CORRECTED AND/OR MITIGATED BY THE GENERAL CONTRACTOR PRIOR TO ADDITIONAL WORK.
SS.	FOR MILLWORK, PROVIDE PRODUCT DATA FOR EACH TYPE OF PRODUCT AND PROCESS SPECIFIED AND INCORPORATED INTO ITEMS OF ARCHITECTURAL WOODWORK DURING FABRICATION, FINISHING AND INSTALLATION. PROVIDE SHOP DRAWINGS SHOWING LOCATION OF EACH ITEM, DIMENSIONED PLANS AND ELEVATIONS, LARGE SCALE DETAILS, ATTACHMENT DEVICES AND OTHER COMPONENTS. PROVIDE SAMPLES FOR EACH SELECTION OF EXPOSED HARDWARE, FINISH, TEXTURE AND PATTERN OF MATERIALS SPECIFIED.
TT.	GENERAL CONTRACTOR SHALL COORDINATE WITH DECOR SUPPLIER FOR INFORMATION FOR BIDDING AND INSTALLATION OF ITEMS SUPPLIED IN THE DECOR PACKAGE.
UU.	CONTACT BETWEEN DISSIMILAR METALS SHALL BE LIMITED. WHEN REQUIRED, THE CONTACT SHALL BE PROTECTED AS REQUIRED.
VV.	REQUIREMENTS FOR NOTIFICATION, FIRE WATCH, RE-TESTING, ETC.
WW.	FURNITURE, OFFICE EQUIPMENT AND OTHER MISCELLANEOUS EQUIPMENT MAY BE PROVIDED BY CLIENT AND NOT INCLUDED IN THIS CONTRACT. GENERAL CONTRACTOR TO VERIFY EQUIPMENT EXTENTS, LOCATION AND COORDINATE AS REQUIRED.
XX.	REMOVE COMBUSTIBLE RUBBISH DURING CONSTRUCTION FROM THE PROJECT LIMITS CONTINUOUSLY AND DISPOSE OF IN A LEGAL MANNER.
YY.	VENDORS ARE RESPONSIBLE FOR DISPOSAL OF SHIPPING/CRATING MATERIALS. VERIFY WITH THE GENERAL CONTRACTOR THE USE OF THE DUMPSTER ON SITE. SUBCONTRACTORS MUST DISPOSE OF THEIR CONSTRUCTION DEBRIS, IF NOT COMPLETED, IT WILL BE COMPLETED AND BACK CHARGED FOR CLEANING. COORDINATE DISPOSAL WITH JOB SUPERINTENDENT.
ZZ.	AT THE TIME OF PROJECT COMPLETION, THE PROJECT LIMITS ARE TO BE THOROUGHLY CLEANED PRIOR TO TURNOVER TO CLIENT.
AAA.	GENERAL CONTRACTOR SHALL PROVIDE THREE (2) SEPARATE FINAL PROJECT CLEANING. THE FIRST CLEAN SHALL INCLUDE A CONSTRUCTION CLEAN, SEAL AND POLISH, PRIOR TO EACH EQUIPMENT INSTALLATION. THE SECOND CLEANING SHALL INCLUDE A WET MOP OF FLOORS AND PROFESSIONAL CLEAN AFTER EQUIPMENT INSTALLATION, PRIOR TO OPENING. CLEANING SCHEDULE SHALL BE VERIFIED WITH CLIENT'S REPRESENTATIVE.



STORE NUMBER: 5037

LOCATION: HUNTLEY

ADDRESS: 12990 ROUTE 47, LOT 4B
HUNTLEY, IL 60142

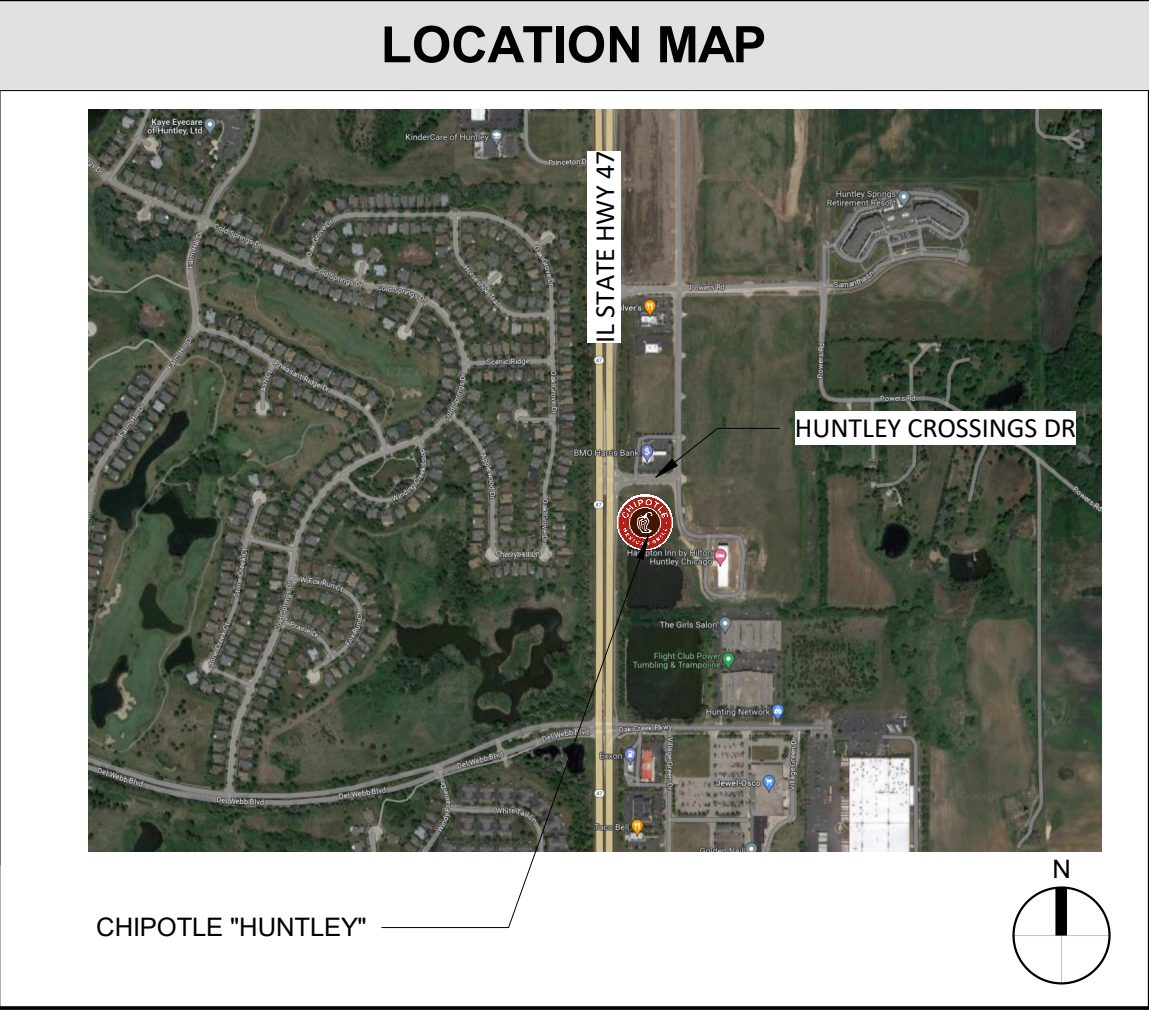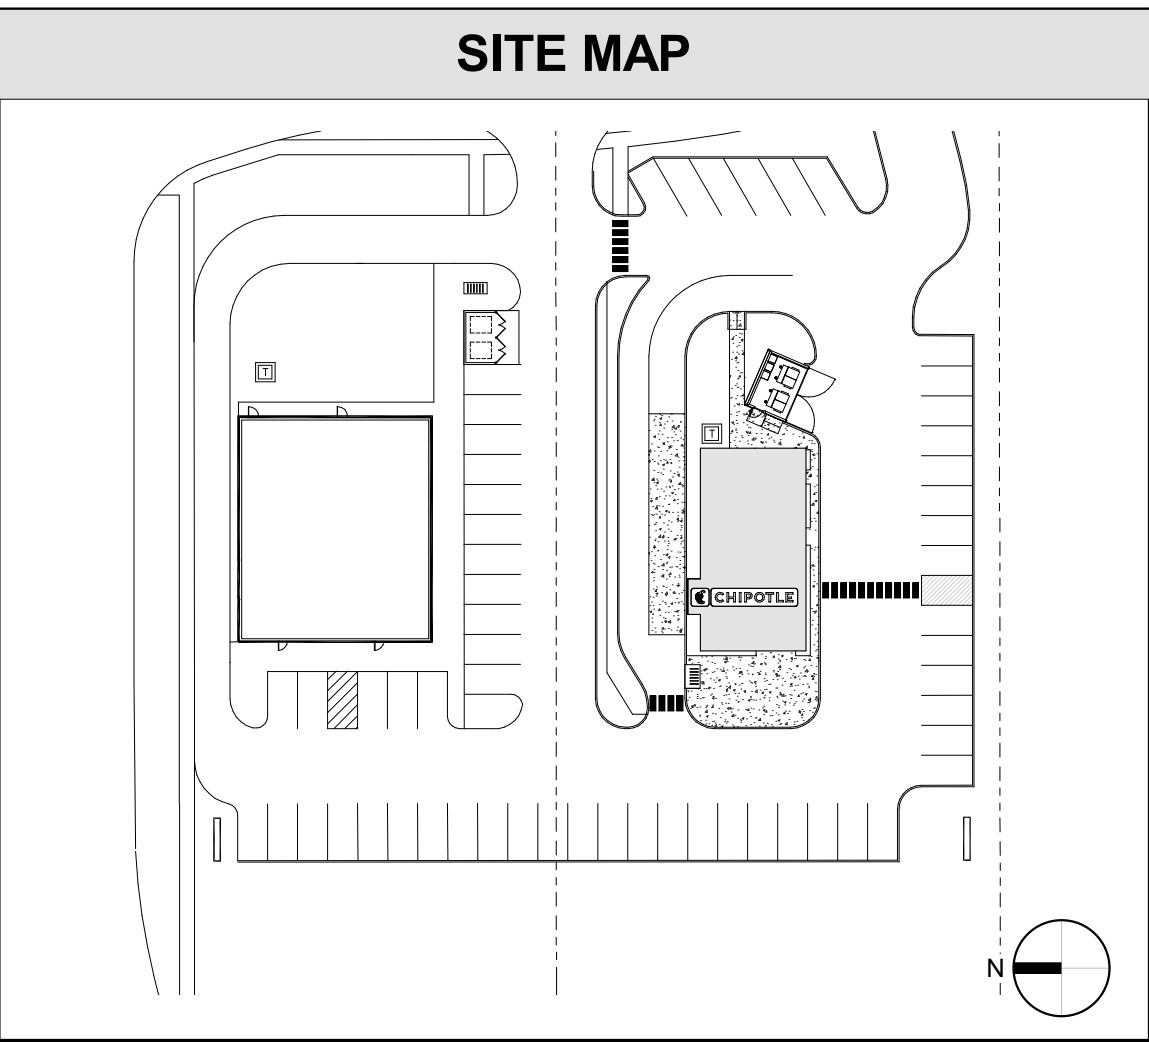

SYMBOL LEGEND			
	EXTERIOR ELEVATION MARKER		COLUMN GRID LABEL
	INTERIOR ELEVATION MARKER		ROOM NAME & NUMBER
	SECTION MARKER		REVISION NUMBER
	SECTION / DETAIL		DOOR NUMBER
	VIEW NAME		MISCELLANEOUS EQUIPMENT NUMBER
	KEYNOTE & WASHROOM ACCESSORIES NUMBER		KITCHEN EQUIPMENT NUMBER
	WALL TAG		FURNITURE NUMBER
	LEVEL TARGET		NORTH ARROW
	DIMENSION TARGET		FINISH TAG

SHELL PERMIT NUMBER: #23-1251	
PROJECT TEAM	
LANDLORD CORE ACQUISITIONS 200 S WACKER DR CHICAGO, IL 60606 CONTACT: ADAM BELL E: abell@coreacq.com P: (224) 470-2211	TENANT CHIPOTLE MEXICAN GRILL PO BOX 182566 COLUMBUS, OH 43218-2566 CONTACT: HEATHER CONLEY E: heather.conley@chipotle.com T: (380) 222-7248 C: (614) 816-1382
ARCHITECT WILKUS ARCHITECTS INC. 15 NINTH AVENUE NORTH HOPKINS, MN 55343 CONTACT: DAVIN LINDOW E: dli@wilkusarch.com T: (952) 843-7055	MECHANICAL ELECTRICAL PLUMBING ENGINEER AYRES ASSOCIATES, INC. 1700 HIGHWAY 36 WEST, SUITE 700 ST. PAUL, MN 55113 CONTACT: EDWARD STUDINSKI E: studnskie@ayresassociates.com T: (651) 604-3155
STRUCTURAL ENGINEER VAA ENGINEERING 2300 BERKSHIRE LANE N, SUITE 200 PLYMOUTH, MN 55441 CONTACT: TERRY MAHR E: tmahr@vaaeng.com T: (763) 577-9119	

REGULATORY AUTHORITIES	
ZONING DEPARTMENT VILLAGE OF HUNTLEY MUNICIPAL COMPLEX 10987 MAIN STREET HUNTLEY, IL 60142 CONTACT: SCOTT BERNACKI E: sbernacki@huntley.il.us T: (847) 515-5248	BUILDING DEPARTMENT VILLAGE OF HUNTLEY MUNICIPAL COMPLEX 10987 MAIN STREET HUNTLEY, IL 60142 CONTACT: MARK FINK E: mfink@huntley.il.us T: (847) 515-5224
FIRE DEPARTMENT FIRE PROTECTION DISTRICT HQ STATION 1118 MAIN STREET HUNTLEY, IL 60142 CONTACT: JOE BUSCHBACHER E: jbuschbacher@huntleyfpd.org T: (847) 669-5066	WATER UTILITY VILLAGE OF HUNTLEY 10987 MAIN STREET HUNTLEY, IL 60142 T: (847) 515-5200
NATURAL GAS UTILITY NICOR GAS PO BOX 190 AURORA, IL 60607 CONTACT: SHARI GETZ E: sgetz@southernco.com T: (815) 261-9431	ELECTRICAL UTILITY COMMONWEALTH EDISON PO BOX 805379 CHICAGO, IL 60680 T: (866) 639-3532
SEWER UTILITY VILLAGE OF HUNTLEY 10987 MAIN STREET HUNTLEY, IL 60142 CONTACT: MARIA ALMANZA E: almanzamaria@countyofoakland.org T: (930) 208-3801	TELEPHONE UTILITY COMCAST BUSINESS T: (877) 533-5676

UTILITY COORDINATOR	
 NOTE TO GENERAL CONTRACTOR FOR ALL WATER, SEWER, NATURAL GAS, & ELECTRICITY UTILITIES CONTACT THE FOLLOWING	HDGROUP, INC. 295 LUNA LN. ERIE, CO 80516 CONTACT #1: MELISSA BALCERAK E: mbalcerak@hdgroupinc.com T: (972) 396-8409 F: (214) 291-5597
 CONTACT #2: KRISTI RHODES E: krhodes@hdgroupinc.com T: (972) 396-8409 EXT 304 F: (214) 291-5597	 CONTACT #3: CAROLYN LETHIN E: cletthin@hdgroupinc.com T: (972) 396-8409 F: (214) 291-5597

SHEET INDEX	
SHEET NO.	SHEET NAME
REVISION	
1 2 3 4	
GENERAL	
G000	COVER SHEET
G001	CODE ANALYSIS - LIFE SAFETY PLAN
G002	ACCESSIBILITY STANDARDS
SPECIFICATIONS	
G010	ARCHITECTURAL SPECIFICATIONS
G011	ARCHITECTURAL SPECIFICATIONS
G012	ARCHITECTURAL SPECIFICATIONS
G013	ARCHITECTURAL SPECIFICATIONS
G014	ARCHITECTURAL SPECIFICATIONS
G015	ARCHITECTURAL SPECIFICATIONS
G016	ARCHITECTURAL SPECIFICATIONS
G017	ARCHITECTURAL SPECIFICATIONS
ARCHITECTURAL	
SP100	SITE PLAN
ARCHITECTURAL	
A101	SLAB WORK PLAN
A110	ARCHITECTURAL FLOOR PLAN
A111	ARCHITECTURAL WALL TYPES
A120	FINISH PLAN
A130	FF&E PLAN
A131	FF&E SCHEDULES
A140	ARCHITECTURAL ROOF PLAN
A201	REFLECTED CEILING PLAN
A210	CEILING DETAILS
A211	LIGHTING DETAILS
A301	EXTERIOR ELEVATIONS
A502	INTERIOR SECTIONS
A601	DOOR & HARDWARE SCHEDULE
A701	ELEVATIONS - INTERIOR DINING
A702	ELEVATIONS - INTERIOR KITCHEN
A710	RESTROOM INFORMATION
A801	FINISH DETAILS - GENERAL
A802	FINISH DETAILS - TILE
A803	FINISH DETAILS - WOOD
STRUCTURAL	
S000	GENERAL STRUCTURAL NOTES
S100	SLAB ON GRADE PLAN AND DETAILS
S200	ROOF FRAMING PLAN
HVAC	
M010	MECHANICAL SPECIFICATIONS
M100	HVAC PLAN
M600	HVAC SCHEDULES
M700	HVAC DETAILS
PLUMBING	
P010	PLUMBING SPECIFICATIONS
P100	PLUMBING PLAN WATER & GAS
P110	PLUMBING PLAN WASTE & VENT
P600	PLUMBING SCHEDULES
P700	PLUMBING DETAILS
ELECTRICAL	
E010	ELECTRICAL SPECIFICATIONS
E100	ELECTRICAL LIGHTING PLAN
E101	LIGHTING SCHEDULES
E110	ELECTRICAL POWER PLAN
E115	ELECTRICAL SITE POWER PLAN
E600	ELECTRICAL SCHEDULES
E700	ELECTRICAL INTERIOR ELEVATIONS
E705	ELECTRICAL INTERIOR ELEVATIONS
E710	ELECTRICAL DETAILS
Grand total: 52	

SIGNAGE VENDOR	
JONES SIGN 1711 SCHEURING ROAD DE PERE, WI 54115 CONTACT : JERRY SZYMANSKI E: jszymanski@jonesign.com T: (920) 241-3933 (EXT 1686)	

SCOPE OF WORK	
TENANT INTERIOR FIT OUT OF A VACANT SHELL SPACE. WORK INCLUDES, BUT IS NOT LIMITED TO, INTERIOR FINISHES, TOILET ROOMS, EXTENSION OF UTILITIES, AND MODIFICATIONS TO ACCOMMODATE A NEW QUICK SERVICE RESTAURANT. OUTDOOR PATIO FURNITURE WILL BE INSTALLED. SIGNAGE IS UNDER A SEPARATE COVER.	

WILKUS ARCHITECTS

CLIENT:

CHIPOTLE MEXICAN GRILL, INC.
PO BOX 182566
COLUMBUS, OH 43218-2566
TELEPHONE: (614) 318-2482
INTERNET: WWW.CHIPOTLE.COM

PROJECT INFORMATION:

STORE NO.: 5037
HUNTLEY
12990 ROUTE 47, LOT 4B
HUNTLEY, IL 60142

SEAL:

PROJECT NO. 2023-0175
DRAWN BY JSB, DVA
CHECKED BY DVA, NSG, KAM, MMW

ISSUE RECORD:

02/12/2024	PERMIT SUBMITTAL
03/15/2024	BID SET
05/03/2024	CONSTRUCTION SET

TITLE:

COVER SHEET

SHEET NUMBER:

G000



(N)	EXISTING CONSTRUCTION	EL	ELEVATION (VERTICAL HEIGHT)	HES	TENANT'S HVAC EQUIPMENT SUPPLIER	MSS	MUSIC SYSTEMS SUPPLIER	SPS	SODA POP SUPPLIER	THS	TENANT'S HARDWARE SUPPLIER	TSS	TENANT'S SMART SAFE SUPPLIER
@	NEW CONSTRUCTION	SS	SUPPORT SIGNAGE	NIC	NOT IN CONTRACT	NO	NUMBER	T	TENANT	TLS	TENANT'S LIGHT/LAMP SUPPLIER	TSV	TENANT'S SIGN VENDOR
ARCH	ABOVE FINISH FLOOR ARCHITECT(URAL)	ELEV	ELEVATION	HVAC	HEATING AND VENTILATING	OC	ON CENTER	TAB	TENANT'S TEST & BALANCE VENDOR	TMB	TENANT'S MENU BOARD SUPPLIER	TYP	TYPICAL
ASS	ALARM SYSTEM SUPPLIER	EQ	EQUAL	ICP	INITIAL COST PROJECTION	OSB	ORIENTED STRAND BOARD	TBD	TO BE DETERMINED, SEE FIELD REFERENCE MANUAL	TMS	TENANT'S MILLWORK SUPPLIER	UNO	UNLESS NOTED OTHERWISE
BD	BOARD	EXT	EXTERIOR	INT	INTERIOR	PDC	PROTECT DURING CONSTRUCTION	TCC	TENANT'S CABLING CONTRACTOR	TPS	TENANT'S PHONE SUPPLIER	VIF	VERIFY IN FIELD
BLDG	BUILDING	FC	FOR CONSTRUCTION	KES	KITCHEN EQUIPMENT SUPPLIER	PES	POINT OF SALE PREPARATION	TEMS	TENANT'S ENERGY MANAGEMENT SYSTEM SUPPLIER	TS	TENANT'S PANELBOARD SUPPLIER	WCS	TENANT'S WALK-IN COOLER SUPPLIER
CMU	CONCRETE MASONRY UNIT	FRP	FIBERGLASS REINFORCED PANEL	MAX	MAXIMUM	PRE	PREPARED	TRS	TENANT'S RAILING SUPPLIER	THS	TENANT'S THERMOSTAT SUPPLIER	WHS	WATER HEATER SUPPLIER
CO2	CO2 SUPPLIER	FRT	FIRE RETARDANT-TREATED	MECH	MECHANICAL	Q	QUARRY TILE	RTU	ROOF TOP UNITS	TS	TENANT'S SAFE SUPPLIER	Ø	DIAMETER OR ROUND
CO2AS	CO2 ALARM SUPPLIER	GA	Gauge	MFR	MANUFACTURER	MR	MISCELLANEOUS						
DM	DIMENSION(S)	GALV	GALVANIZED	MIN	MINIMUM								
EACH	EACH	GC	GENERAL CONTRACTOR	MISC	MISCELLANEOUS								

LIFE SAFETY SYSTEMS SHALL BE DESIGNED PER APPLICABLE FIRE PREVENTION CODE, ORDINANCE OR LAW.
 B. POST "NO PARKING - FIRE LANE" SIGNS ALONG APPROVED VEHICULAR ACCESS ROADS. COORDINATE LOCATIONS WITH LOCAL AUTHORITY HAVING JURISDICTION.
 C. AN ALL WEATHER FIRE ACCESS ROAD SHALL BE IN PLACE BEFORE ANY COMBUSTIBLE MATERIALS ARE PLACED ON SITE. COORDINATE WITH LOCAL AUTHORITY HAVING JURISDICTION.
 D. SEPARATELY IDENTIFIED AREAS SHALL BE UNOBSTRUCTED. ACCESS GATES SHALL BE APPROVED PRIOR TO INSTALLATION AND SHALL BE IN COMPLIANCE WITH O.S.H.A. GUIDELINES.
 E. COMMERCIAL DUMPSTERS OR CONTAINERS WITH A CAPACITY OF ONE AND A HALF CUBIC YARDS OR GREATER SHALL NOT BE STORED OR PLACED WITHIN THE FOOT COT OF CONSTRUCTION. OTHER SPECIAL TYPES OF AUTOMATIC FIRE-EXTINGUISHING SYSTEMS AND OTHER FIRE PROTECTION SYSTEMS AND APPURTENANCES SHALL BE SUBMITTED TO AUTHORITIES HAVING JURISDICTION FOR REVIEW AND APPROVAL PRIOR TO INSTALLATION.
 F. BUILDING ADDRESS NUMBERS SHALL BE PROVIDED AT THE FRONT OF THE TENANT SPACE AND SHALL BE VISIBLE AND LEGIBLE FROM THE PUBLIC RIGHT OF-WAY AND A MINIMUM OF 6" HIGH. NUMBERS SHALL CONTRAST WITH THEIR BACKGROUND. BUILDING NUMBERS SHALL BE PROVIDED AND INSTALLED BY THE GENERAL CONTRACTOR.
 G. THE ADDRESS SHALL BE PERMANENTLY POSTED ON UTILITY SERVICE DISCONNECTS IN NUMBERS A MINIMUM OF 1" TALL AND ON THE SERVICE DOOR IN NUMBERS A MINIMUM OF 4" TALL.
 H. A KEY PLAN IS TO BE PROVIDED AND INSTALLED BY THE GENERAL CONTRACTOR. VERIFY WITH THE LOCAL AUTHORITY THIS REQUIREMENT AND COORDINATE LOCATION AS REQUIRED.
 I. COMPLETE PLANS AND SPECIFICATIONS FOR THE FIRE ALARM SYSTEMS: FIRE-EXTINGUISHING SYSTEMS, INCLUDING AUTOMATIC SPRINKLERS AND WET AND DRY PIPE AND SUBMITTED TO THE LOCAL AUTHORITY HAVING JURISDICTION FOR REVIEW AND APPROVAL PRIOR TO INSTALLATION.
 J. ENGINEERED AUTOMATIC FIRE SPRINKLER SYSTEM PLANS, CALCULATIONS AND SPECIFICATIONS SHALL BE DESIGNED BY AN APPROVED INSTALLER AND SUBMITTED TO THE LOCAL AUTHORITY HAVING JURISDICTION PRIOR TO ANY WORK BEING COMPLETED TO THE SYSTEM.
 K. ENGINEERED AUTOMATIC FIRE ALARM AND DETECTION SYSTEM PLANS, CALCULATIONS AND SPECIFICATIONS SHALL BE DESIGNED BY AN APPROVED INSTALLER AND SUBMITTED TO THE LOCAL AUTHORITY HAVING JURISDICTION PRIOR TO ANY WORK BEING COMPLETED TO THE SYSTEM.
 L. THE CENTER OF FIRE ALARM INITIATING DEVICES (BOXES) SHALL BE LOCATED ABOVE THE LEVEL OF THE FLOOR, WORKING PLATFORM, GROUND SURFACE OR SIDEWALK AS REQUIRED TO MEET APPLICABLE CODES, ORDINANCES AND LAWS.
 M. THE FIRE SPRINKLER SYSTEM SHALL BE SERVED BY A MONITORING METHOD AS REQUIRED BY THE APPLICABLE CODE, ORDINANCE OR LAW.
 N. THE INSTALLATION OF THE FIRE SUPPRESSION SYSTEM, INCLUDING ANSUL SYSTEM, SHALL COMPLY WITH THE BUILDING CODE AND THE FIRE SUPPRESSION SYSTEM WILL BE INSTALLED, PERMITTED, INSTALLED AND INSPECTED UNDER A SEPARATE DEFERRED PERMIT APPLICATION.
 O. THE INSPECTION, HYDROSTATIC TESTING AND FLUSHING OF THE AUTOMATIC FIRE SPRINKLER SYSTEM AND/OR FIRE HYDRANTS SHALL BE WITNESSED BY THE PROPER FIRE DEPARTMENT REPRESENTATIVE AND NO UNDERGROUND PIPING SHALL BE COVERED OR HIDDEN UNTIL AFTER THE PROPER FIRE DEPARTMENT REPRESENTATIVE HAS BEEN NOTIFIED AND GIVEN NO LESS THAN 48 HOURS IN WHICH TO INSPECT SUCH INSTALLATIONS.
 P. FIRE ALARM SYSTEMS SHALL BE DESIGNATED AS CLASS "A" SYSTEMS.
 Q. USED EGRESS DOORS SHALL BE OPENABLE FROM THE INSIDE WITHOUT THE USE OF A KEY OR ANY SPECIAL KNOWLEDGE OR EFFORT AND SHALL COMPLY WITH THE DISTRICT OF COLUMBIA TRAVEL, SPECIAL LOCKING DEVICES SHALL BE OF AN APPROVED TYPE.
 R. EXITS SHALL BE ILLUMINATED AT ANY TIME THE BUILDING IS OCCUPIED WITH LIGHTS HAVING AN INTENSITY OF NOT LESS THAN 11.0 LUX AT FLOOR LEVEL, OR AS DIRECTED BY LOCAL AGENCY CODE.
 S. EXIT SIGNS TO BE PROVIDED AND INSTALLED AS REQUIRED BY APPLICABLE CODES, ORDINANCES AND LAWS.
 T. PROVIDE APPROVED EXITING ILLUMINATION AND ILLUMINATED EXIT SIGNS WHICH ARE POWERED FROM SEPARATE CIRCUITS AND COMPLY WITH THE BUILDING CODE.
 U. OCCUPANT LOAD SIGN WITH MINIMUM 1" LETTERS AND NUMBERS SHALL BE POSTED NEAR MAIN EXIT.
 V. EXIT LIGHTING AND SIGNS SHALL HAVE 6" HIGH LETTERING IN ACCORDANCE WITH LOCAL CODES. PROVIDE LOW LEVEL EXIT SIGNS PER CODE REQUIREMENTS.
 W. FIRE DEPARTMENT FINAL INSPECTION REQUIRED.
 X. EXITS, EXIT SIGNS, FIRE ALARM PANELS, FIRE EXTINGUISHER LOCATIONS, AND STANDPIPE CONNECTIONS SHALL NOT BE CONCEALED BY ANY DECORATIVE MATERIAL.
 Y. FIRE EXTINGUISHER NOTES
 a. PROVIDE AND INSTALL FIRE EXTINGUISHERS AS DIRECTED BY AUTHORITY HAVING JURISDICTION. EXTINGUISHERS IN BACK OF HOUSE AREAS MAY BE IN BRACKETS, PUBLIC AREAS ARE TO BE ENCLOSED IN RECESSED CABINETS, PAINTED TO MATCH ADJACENT WALL FINISH.
 b. PROVIDE "K" TYPE FIRE EXTINGUISHER IN KITCHEN AREAS, WITHIN 30'-0" OF TRAVEL FROM ANY AREA OF THE KITCHEN OR FOOD PREPARATION AREAS. VERIFY INSTALLATION LOCATIONS WITH LOCAL FIRE MARSHAL PRIOR TO INSTALLATION.
 c. 5 LB. "ABC" FIRE EXTINGUISHERS ARE REQUIRED WITHIN 75'-0" OF TRAVEL FROM ANY POINT IN PUBLIC AREAS. THEY MUST BE MOUNTED CONSPICUOUSLY, BE PLACED ALONG NORMAL TRAVEL PATHS AND EXIT WAYS. VERIFY INSTALLATION LOCATIONS WITH LOCAL FIRE MARSHAL PRIOR TO INSTALLATION.

*INCLUDES STATE AND LOCAL PROVISIONS TO THE BUILDING CODE	
BUILDING CODE:	2018 INTERNATIONAL BUILDING CODE
MECHANICAL CODE:	2018 INTERNATIONAL MECHANICAL CODE
PLUMBING CODE:	2014 ILLINOIS PLUMBING CODE
ENERGY CODE:	2018 ILLINOIS ENERGY CONSERVATION CODE
FUEL GAS CODE:	2018 INTERNATIONAL FUEL GAS CODE
ELECTRICAL CODE:	2017 NATIONAL ELECTRICAL CODE
FIRE CODE:	2018 INTERNATIONAL FIRE CODE
FOOD CODE:	2017 FDA FOOD CODE; ILLINOIS FOOD CODE PART 750
ACCESSIBILITY CODE(S):	2018 ILLINOIS ACCESSIBILITY CODE

FUNCTION OF SPACE	SQUARE FOOTAGE	LOAD FACTOR	OCCUPANT LOAD
STANDING SPACE	92	5 SF (NET)	19
FIXED SEATING	29 SEATS	1 SEAT/OCC.	29
FIXED SEATING - BOOTH	188"	24" BOOTH LENGTH/ OCC..	08
KITCHEN (COMM.)	1,089	200 SF (GROSS)	06
BUSINESS AREA	43	150 SF (GROSS)	01
POSTED OCCUPANT LOAD:			63

RESTAURANT SEATING COUNT	
INTERIOR SEATING COUNT	37
EXTERIOR (PATIO) SEATING COUNT	20
TOTAL SEATING COUNT	57

CONSTRUCTION TYPE	TYPE V-B (EXISTING)
OCCUPANCY TYPE	A-2
AREA FACTOR	SPRINKLERED, SINGLE STORY (EXISTING)
BUILDING AREA	2,350 SQ FT (EXISTING)
OCCUPANT LOAD	63 OCC.

OCCUPANCY GROUP & FUNCTION	GENERAL DESCRIPTION OF SITE
A-2; RESTAURANT	FIRST TENANT WITHIN EXISTING SHELL FOR RESTAURANT TENANT IMPROVEMENT

OCCUPANCY CLASSIFICATION	A-2 (UNCHANGED)
ALLOWABLE BUILDING HEIGHT	40'-0" (UNCHANGED)
EXISTING BUILDING HEIGHT (PER CHAPTER 2 DEFINITION)	14'-9" (UNCHANGED)
EXISTING TOTAL BUILDING HEIGHT	20'-8" (UNCHANGED)
Aa = ACTUAL ALLOWABLE AREA	Aa = 6,000 SQ. FT.
EXISTING BUILDING AREA	2,350 SF (UNCHANGED)

FIRE RESISTANCE RATING REQUIREMENTS FOR BUILDING ELEMENTS		
BUILDING ELEMENT		FIRE RATING REQUIRED
PRIMARY STRUCTURAL FRAME		0 HOUR (UNCHANGED)
BEARING WALLS	EXTERIOR	0 HOUR (UNCHANGED)
	INTERIOR	0 HOUR (UNCHANGED)
NON-BEARING WALLS	EXTERIOR	0 HOUR (UNCHANGED)
NON-BEARING WALLS AND PARTITIONS	INTERIOR	0 HOUR (UNCHANGED)
FLOOR CONSTRUCTION		0 HOUR (UNCHANGED)
ROOF CONSTRUCTION		0 HOUR (UNCHANGED)

TYPE OF SPACE	FINISH CLASSIFICATION
INTERIOR EXIT PASSAGEWAYS	B (UNCHANGED)
COORIDORS AND ENCLOSURE FOR EXIT ACCESS STAIRS	B (UNCHANGED)
ROOMS AND ENCLOSED SPACES	C (UNCHANGED)

SPRINKLER SYSTEM:	SPRINKLERED (EXISTING)
COMMENTS:	EXISTING SPRINKLER SYSTEM IN ENCLOSED ROOM ONLY ACCESSED FROM THE EXTERIOR IS REQUIRED BY JURISDICTION
FIRE ALARM & DETECTION SYSTEM:	REQUIRED - LOCATED IN SPRINKLER ROOM
FIRE EXTINGUISHERS:	REQUIRED - QUANTITY AND LOCATION PER AHJ

The diagram is divided into two main sections: "FUNCTION OF SPACE" and "EGRESS AT DOORS".

FUNCTION OF SPACE:

- MAXIMUM EXIT ACCESS TRAVEL DISTANCE (MINIMUM WIDTH AS INDICATED IN CODE ANALYSIS):** Represented by a dashed line with an arrow pointing right.
- ACCESSIBLE PATH OF EGRESS:** Represented by a dashed line with an arrow pointing right.
- 0' - 0" - (0' - 0")** EXIT ACCESS TRAVEL DISTANCE (COMMON PATH IF APPLIES)
- PROPOSED FIRE EXTINGUISHER LOCATION - GENERAL CONTRACTOR TO VERIFY THE EXACT TYPE, LOCATION(S) AND QUANTITIES WITH THE AUTHORITIES HAVING JURISDICTION PRIOR TO ORDERING AND INSTALLING FIRE EXTINGUISHERS**
- EMERGENCY LIGHTING & EXIT SIGNS:**
- WALL MOUNTED EXIT SIGN**
- NOTE: ALL EXIT LIGHTS ON EXTERIOR DOORS SHALL HAVE AN EXTERIOR EMERGENCY REMOTE HEAD LINKED TO IT**

FUNCTION OF SPACE (continued):

- ASSEMBLY, UNCONCENTRATED (STANDING SPACE)**
- ASSEMBLY AREA WITH FIXED SEATS**
- ASSEMBLY AREA WITH FIXED SEATS (BOOTHES)**
- KITCHENS, COMMERCIAL AREA**
- BUSINESS AREA**
- UNOCCUPIED AREAS (RESTROOMS, UNOCCUPIABLE SPACES, MEANS OF EGRESS)**

EGRESS AT DOORS:

- EGRESS BREAKDOWN:**
- OCCUPANTS SERVED**
- EXIT WIDTH REQUIRED**
- EXIT WIDTH PROVIDED**


G001

ILLINOIS ACCESSIBILITY CODE


ALL INTERIOR CONSTRUCTION WITHIN THE SCOPE OF THIS PROJECT IS REQUIRED TO BE ACCESSIBLE AS SET FORTH IN THE "ILLINOIS ADMINISTRATIVE CODE, TITLE 71, CHAPTER 1, SUBCHAPTER b, PART 400. SECTIONS INDICATED ON THIS SHEET REFERENCE THE "2010 ADA STANDARDS FOR ACCESSIBLE DESIGN, UNLESS NOTED OTHERWISE.

DOORS


- Doors, doorways, and gates that are part of an accessible route shall comply with 404.
- Door openings shall provide a clear width of 32 inches, unless the opening is more than 24 inches deep, in which case the clear width of the opening shall be 36 inches. For swinging doors, the clear width shall be measured between the face of the door and the stop, with the door open 90 degrees.
- There shall be no projections into the clear opening lower than 34 inches. Projections into the clear opening between 34 inches and 80 inches shall not exceed 4 inches.
- In accordance with 404.2.3 exception 2, door closers and stops shall be permitted to be a minimum of 78 inches above the floor or ground.
- Maneuvering clearances at doors and gates shall comply with 404.2.4.
- Fire doors shall have a minimum opening force allowable by the appropriate administrative authority.
- Hinged doors other than fire doors shall have an opening force of 5 pounds maximum.
- Sliding doors shall have an opening force of 5 pounds maximum.
- Door and gate surfaces shall comply with 404.2.10.
- Doors shall be permitted to swing into turning spaces, per 304.4.
- Two doors in a series shall comply with Illinois Accessibility Code, Illustration B, Figure 26.

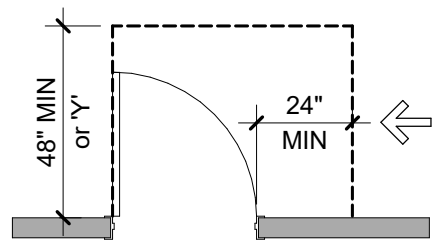


NOTE: Y = 54" MIN.
if door has a closer

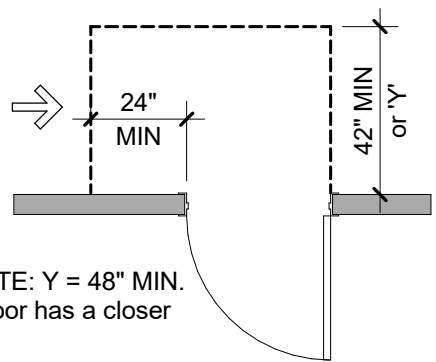



Latch-Side Approaches - Swinging Doors

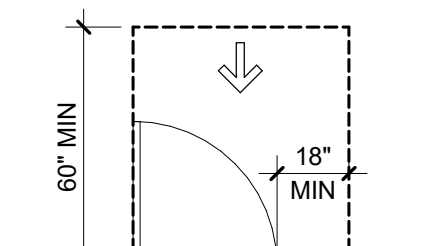


NOTE: X = 12" MIN.
if door has both a
closer and a latch

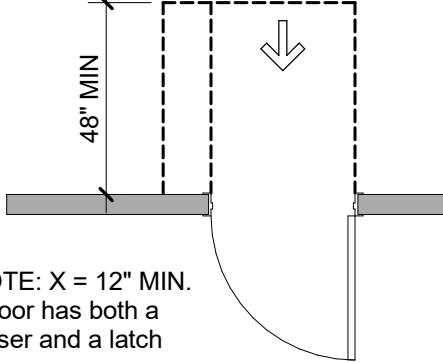


Front Approaches - Swinging Doors

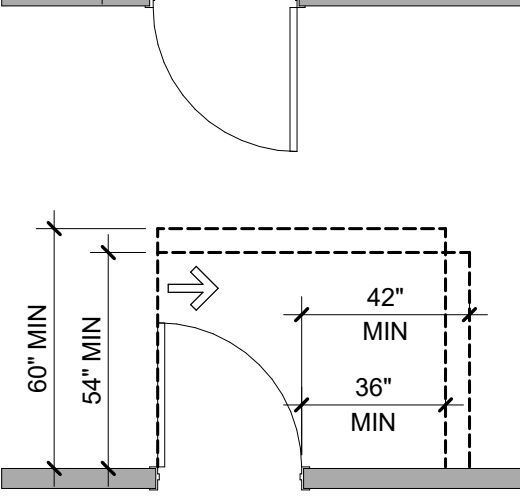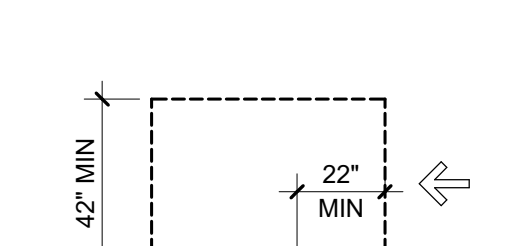


Hinge-Side Approaches - Swinging Doors

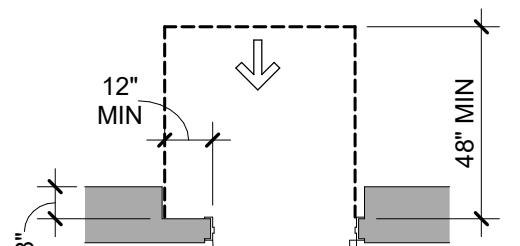



NOTE:
Door has
both a closer
and a latch

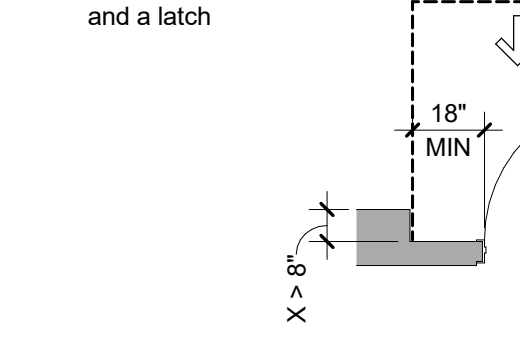


Recessed Doors and Gates

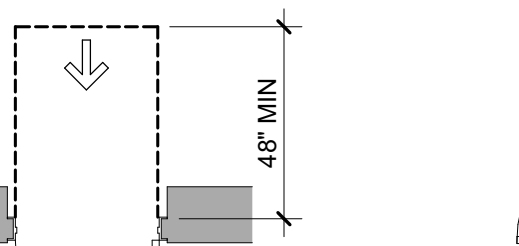

NOTE:
Door can have
either a latch
OR closer, but
not both

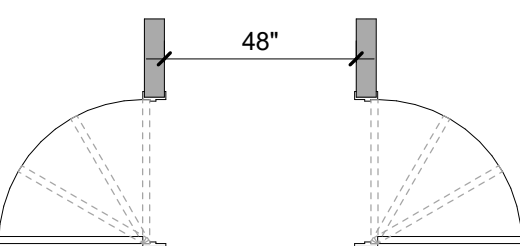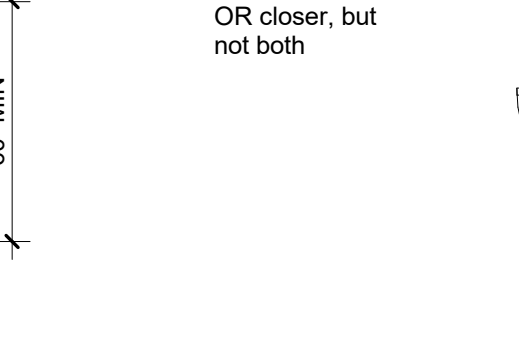

NOTE:
Door can have
either a latch
OR closer, but
not both

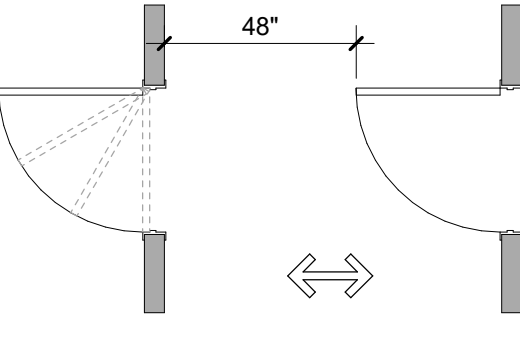


Doors in Series and Gates in Series


RESTROOMS & DRINKING FOUNTAINS

- Where toilet facilities are provided, they shall comply with 213. Where toilet rooms are provided, each toilet room shall comply with 603.
- Where toilet compartments are provided, at least one toilet compartment shall comply with 604.8.1. In addition to the compartment required to comply with 604.8.1, at least one compartment shall comply with 604.8.2 where six or more toilet compartments are provided, or where the combination of urinals and water closets totals six or more fixtures.
- Mirrors located above lavatories or countertops shall be installed with the bottom edge of the reflecting surface 40 inches maximum above finish floor or ground. Mirrors not located above lavatories or countertops shall be installed with the bottom edge of the reflecting surface 35 inches maximum above the finish floor or ground.
- Coat hooks shall be located within one of the reach ranges specified in 308. Shelves shall be located 40 inches minimum and 48 inches maximum above the finish floor.


- Water closets shall comply with 604.2 through 604.8.
- Water closets shall be located 18" horizontally from the sidewall to the center of the toilet (Section 400.31(n)(5)(B)(i) and 400, Illustration B, Figure 28).
- Toilet paper dispensers shall comply with Illinois Accessibility Code, Illustration B, Figure 30, measured to the centerline of the dispenser. The outlet of the dispenser shall not be located behind grab bars. Dispensers shall not be of a type that controls delivery or that does not allow continuous paper flow.
- Grab bars shall be provided at water closets and shall comply with 609.
- Urinals shall comply with 605 and shall be either wall-hung or stall type urinals.
- Lavatories shall comply with 606. Faucets for lavatories shall comply with 606.4. Exposed pipes under lavatories shall be insulated or otherwise protected to prevent against contact.
- Drinking Fountains shall comply with sections 307 and 602.

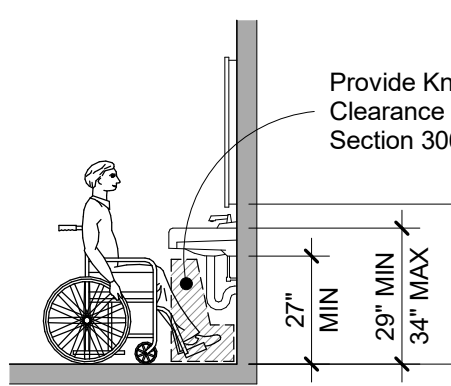

Clearances & Heights at Lavatory

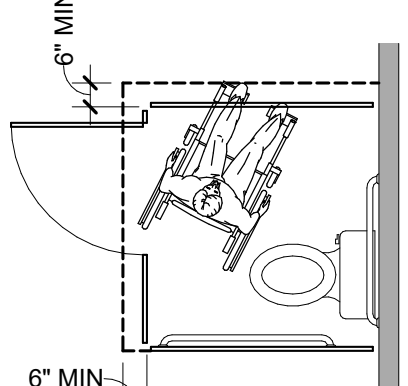


Stall Compartment Toe Clearance

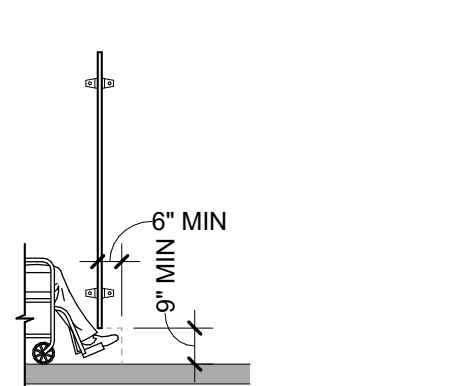


Drinking Fountain Clearance
and Spout Location

REACH RANGES,
CONTROLS &
OPERATING MECHANISMS


- Reach ranges shall comply with 308.
- Operable parts shall comply with 309 and shall be placed within one or more of the reach ranges specified in 308.
- In accordance with 309.4, operable parts shall be operable with one hand and shall not require tight grasping, pinching, or twisting of the wrist. The force required to activate operable parts shall be 5 pounds maximum.

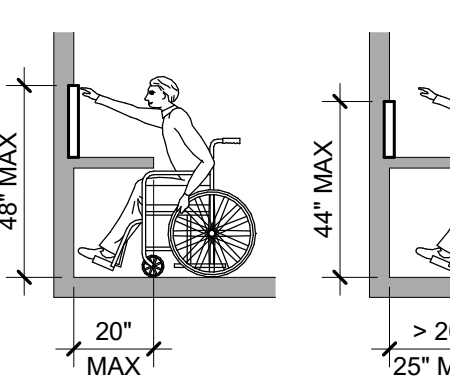


Obstructed Forward Reach

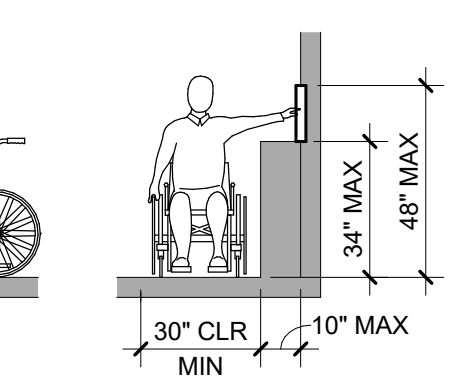

Obstructed Side Reach

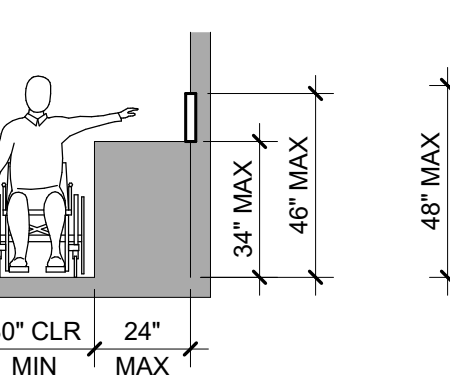


Unobstructed Forward Reach

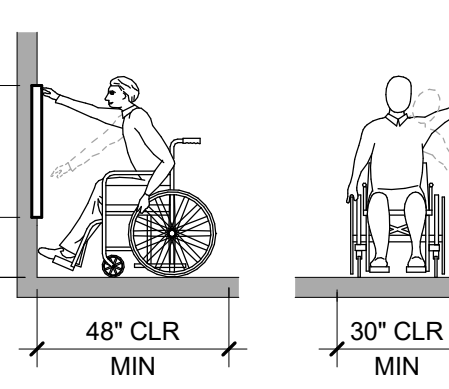


Unobstructed Side Reach

PATH OF TRAVEL


- In accordance with 206.2.4, at least one accessible route shall connect accessible building or facility entrances with all accessible spaces and elements within the building or facility, which are otherwise connected by a circulation path unless exempted by 206.2.3, exceptions 1-7.
- The running slopes of walking surfaces that are part of an accessible route shall not be steeper than 1:20 with a cross slope that is not steeper than 1:48.
- Changes in level shall comply with 303.
- The clear width of walking surfaces on an accessible route shall comply with 403.5.1.
- The clear width at turns along an accessible route shall comply with 403.5.2.
- In accordance with 403.5.3, an accessible route with a clear width of less than 60 inches shall provide passing spaces at intervals of 200 feet.
- Clearances at common-use circulation paths within employee work areas shall comply with 206.2.8.

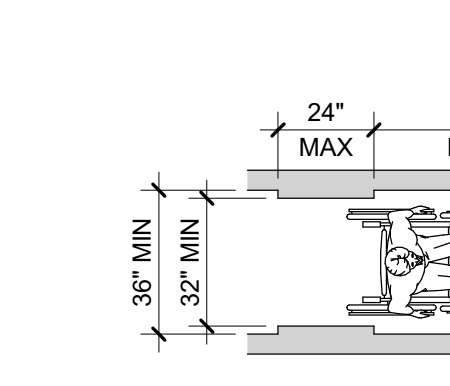

Clear Width of an Accessible Route

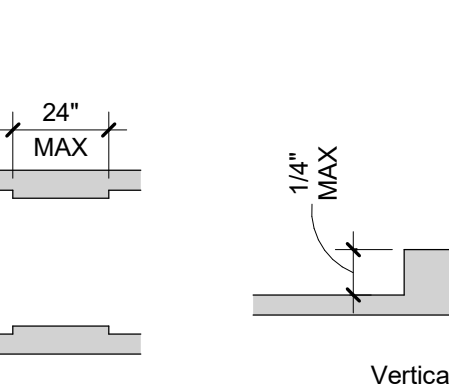


Changes in Level

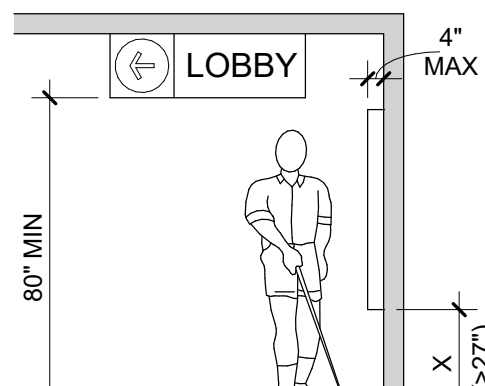


Walking Parallel To A Wall

SEATING AT TABLES
& COUNTERS


- Where dining surfaces are provided for the consumption of food and drink, at least 5 percent of the seating spaces and standing spaces at the dining surfaces shall comply with 902. In addition, where work surfaces are provided for use by other than employees, at least 5 percent shall comply with 902. Confirm actual seat counts with Table 221.2.1.
- Dining surfaces and work surfaces required to comply with 902 and the IL Accessibility Code, Illustration B, Figure 50, and shall be dispersed throughout the space or facility containing dining surfaces and work surfaces.
- Dining surfaces and work surfaces shall comply with 902.2 and 903.3.

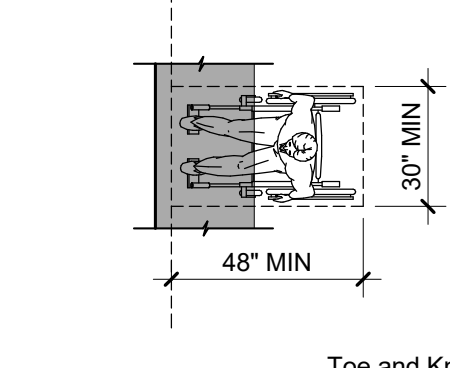

Toe and Knee Clearances

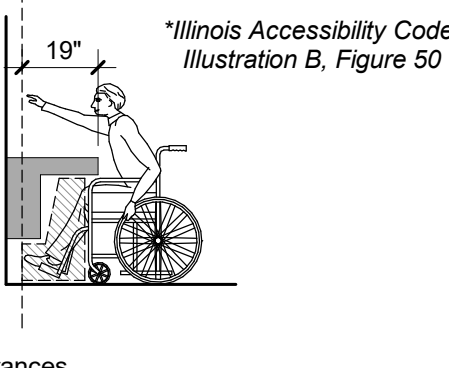


*Illinois Accessibility Code,
Illustration B, Figure 50

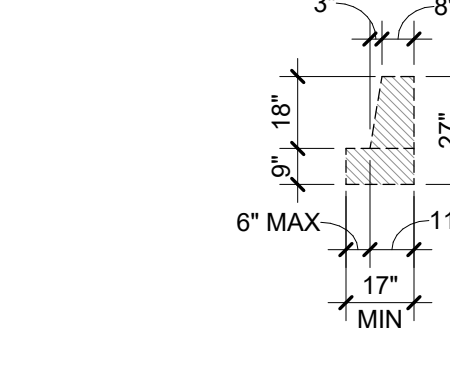

Full Knee Clearance
@ Additional Depth
Knee
Clearance
Toe
Clearance

SIGNAGE


- Signs shall be provided in accordance with 216 and shall comply with 703.
- Signs identifying permanent rooms and spaces shall comply with 703.1, 703.2, and 703.5. Where pictograms are provided as designations of permanent rooms and spaces, the pictograms shall comply with 703.6 and shall have text descriptors complying with 703.2 and 703.5.
- Signs that provide direction to or information about spaces and facilities shall comply with 703.5.
- Signs for means of egress shall comply with 216.4.
- Where more than one check-out aisle is provided, check-out aisles complying with 904.3 shall be identified by the International Symbol of Accessibility complying with 703.7.2.1. Where check-out aisles are identified by numbers, letters, or functions, signs identifying check-out aisles complying with 904.3 shall be located in the same location as the check-out aisle identification.

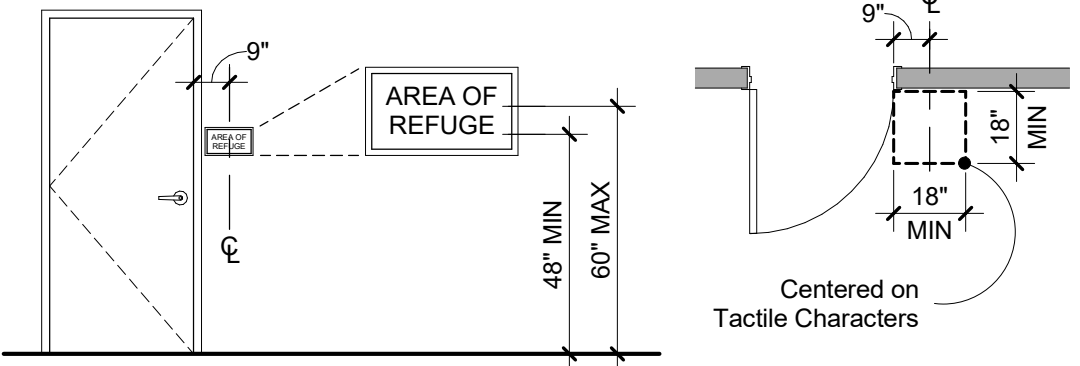

Centered on
Tactile Characters

FOODSERVICE LINES,
TABLEWARE AREAS &
CHECKOUT AISLES

- Where check-out aisles are provided, check-out aisles complying with 904.3 shall be provided in accordance with Table 227.2 and shall be dispersed.
- Where provided, at least one of each type of sales counter and service counter shall comply with 904.4. Where counters are dispersed throughout the building or facility, counters complying with 904.4 also shall be dispersed.
- Food service lines shall comply with 904.5. Where self-service shelves are provided, at least 50 percent, but no fewer than one, of each type provided shall comply with 308.
- Queues and waiting lines servicing counters or check-out aisles required to comply with 904.3 or 904.4 shall comply with 403.
- Check-out aisles and sales and service counters shall comply with the applicable requirements of 904.
- All points of counters required to comply with 904 shall be located adjacent to a walking surface complying with 403.

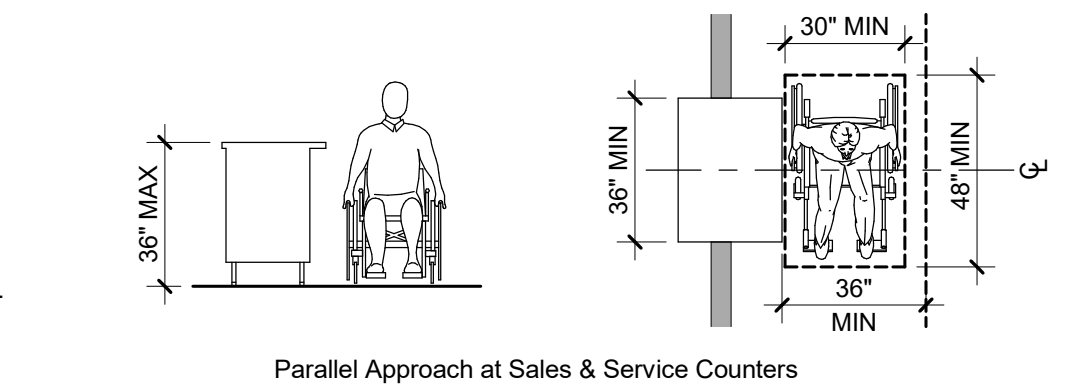

Parallel Approach at Sales & Service Counters

CONSULTANT:



CLIENT:




COPYRIGHT 2024
THIS DRAWING IS AN INSTRUMENT OF SERVICE AND
AS SUCH REMAINS THE PROPERTY OF CHIPOTLE
MEXICAN GRILL, INC. PERMISSION FOR USE OF THIS
DOCUMENT IS LIMITED AND CAN BE EXTENDED ONLY
BY WRITTEN AGREEMENT WITH CHIPOTLE MEXICAN
GRILL, INC.

PROJECT INFORMATION:

STORE NO.: 5037
HUNTLEY
12990 ROUTE 47, LOT 4B
HUNTLEY, IL 60142

SEAL:

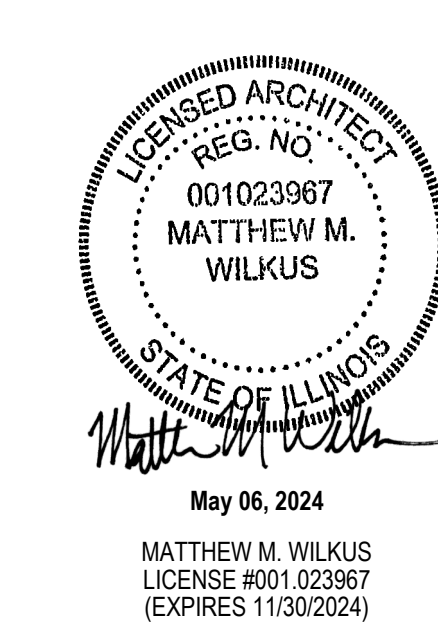

PROJECT NO. 2023-0175
DRAWN BY JSB_DVA
CHECKED BY DVA, NSG, KAM, MMW

ISSUE RECORD:
02/12/2024 PERMIT SUBMITTAL
03/15/2024 BID SET
05/03/2024 CONSTRUCTION SET

REVISIONS:

TITLE:

ACCESSIBILITY
STANDARDS

SHEET NUMBER:

G002

2.1 Materials: A. Resinous Flooring: Manufacturer: aiflooring - Contact: 1218 West 41st Street, Suite B, Tulsa, Oklahoma 74107. Phone: 918-445-0627 2.1 Flooring System: A. System Description: Clear, thin film system 18-22 mils thick with texture agent added for slip resistance. - TerraPrime: A 2 component, 100% solids clear polyamide-cured epoxy coating. - TerraThane Satin: A 2 component, 90% solids polyurea clear finish coat. - TerraGrip: A graded, plastic aggregate added to finish coat for slip resistance. 2.3 Product Substitutions: A. Substitutions: No substitutions permitted. 2.4 Source Quality: A. Source Quality: Obtain resinous materials, including patching and leveling materials from a single manufacturer. 3.1 Manufacturer's Instructions: A. Compliance: Comply with manufacturer's product data, including product technical data sheets and application instructions. 3.2 Examination: A. Site Verifications of Conditions: Verify substrate conditions, which have been previously installed under other sections, are acceptable for product installation in accordance with manufacturer's instructions. - Before applying materials, inspect surfaces to receive new materials and report any unsatisfactory conditions. Absence of any such report shall constitute installer's acceptance of surfaces as satisfactory for installing materials. 3.3 Preparation: A. Adjacent Surfaces Protection: Protect adjacent work areas and finish surfaces from damage during product installation. B. Surface Preparation: - Mechanical Cleaning: Concrete floor surfaces receiving polymer flooring systems shall be thoroughly cleaned and prepared by shotblasting and/or diamond grinding. - Patching Damaged Substrate: Holes, voids, static cracks, and other substrate surface defects should be patched and repaired according to manufacturer's recommendations. - Prepare and clean control joints well and fill with an appropriate elastomeric. 3.4 Installation: A. Resinous Flooring Installation: The following are abbreviated guidelines that should provide for basic application steps for the installation of the systems. Detailed instructions should be obtained from the manufacturer. - Patching: After substrate preparation, surface defects shall be patched according to manufacturer's recommendations. - Priming: Apply aiflooring TerraPrime, 100% solids epoxy primer, at a rate of 125-150 square feet per gallon. Allow 6-12 hours (depending on temperatures) of cure before applying finish coat. Finish coat must be applied within 24 hours of TerraPrime application. - Finish Coat: Apply aiflooring TerraThane Satin, 90% solids polyurea topcoat, at a rate of 200 square feet per gallon. TerraGrip should be added to the TerraThane mix at a rate of 1 pint per 3 gallon kit for slip resistance. Note that TerraThane Satin must be metered out by notched squeegee prior to rolling. B. Cleaning: Remove temporary coverings and protection of adjacent work areas. Repair or replace damaged installed products. Clean installed products in accordance with manufacturer's instructions prior to Owner's acceptance. Remove construction debris from project site and legally dispose of debris. 3.5 Protection: A. Protection: Protect installed product and finish surfaces from damage during construction.	3.1 Installation A. Surface Conditions - Examine substrate, with installer present, for conditions affecting performance of finish. Correct conditions detrimental to timely and proper work. Do not proceed until unsatisfactory conditions are corrected. - Verify that base slab meets finish and surface profile requirements in Division 3 Section "Cast-In-Place Concrete," and Project Conditions above. - Prior to application, verify that floor surfaces are free of construction latents. B. Application The following RetroPlate process will be followed as listed below: A concrete grinding machine must be used. Please proceed accordingly. The process is as follows: - Floors should be started using 50, 80 or 100 grit diamond pucks depending on the condition of the slab. - Clean the floor using automatic scrubber or comparable. - Grind floor using 200 grit resin diamonds. - Clean the floor using automatic scrubber or comparable. - Apply RetroPlate 99 to floor at 200 sq. ft. per gallon, scrubbing product into the floor and allowing product to soak until turning slick. If it becomes sticky, apply water to the surface as necessary, leaving the product on the floor for at least 60 minutes. - Grind floor using 400 grit resin diamonds. - Clean the floor using automatic scrubber or comparable. - Clean and remove any excess RetroPlate. Let the floor dry overnight. - Continue the polishing process using 800 grit resin diamonds. - Clean the floor using automatic scrubber or comparable. - Alternately, depending on slab condition, grind floor using 1200-1500 grit resin diamonds. - Clean the floor using automatic scrubber or comparable. - The same process will be used for new floors as well as rehab floors. Floor prep for the rehab floors will be separate. - Apply an even coat of RetroGuard Sealer with a brush, roller, or low-pressure sprayer, and when surface is dry, burnish the floor with a black burnishing pad. Apply a second coat of RetroGuard one hour after the initial application, and again burnish the floor with a black burnishing pad. - Do not walk on surface for 12 hours, and do not introduce any water or moisture for at least 48 hours, allowing for proper drying and setting of RetroPlate and RetroGuard. Water will minimize the sealing properties of RetroPlate and RetroGuard. C. Start any of the floor finish applications in presence of manufacturer's technical representative. D. Sealing, Hardening and Polishing of Concrete Surface - Concrete must be in place a minimum of 28 days or as directed by the manufacturer before application can begin. - Application is to take place at least 10 days to the prior to racking and other in-store accessory installation, thus providing a complete, uninhibited concrete slab for application. - Only a certified applicator shall apply RetroPlate 99. Procedures must be followed as recommended by the product manufacturer and as required to match approved test sample. - Achieve waterproofing, hardening, dust-proofing, and abrasion resistance of the surface without changing the natural appearance of the concrete, except for the sheen. - Polish to a level 2 shine. E. Workmanship and Cleaning - The premises shall be kept clean and free of debris at all times. - Remove spatter from adjoining surfaces, as necessary. - Repair damages to surface caused by cleaning operations. - Remove debris from jobsite - Dispose of materials in separate, closed containers in accordance with local regulations.	H. Accessories - Reinforcing bars: ASTM A615, Grade 60, deformed billet steel bars of sizes indicated. - Wall weeps: Dur-O-Wal D/A 1006 "Cell Vent", clear flexible polypropylene co-polymer. - Compressible joint material: Dur-O-Wal "Rapid Soft-Joint" D/A 2010. - Bond breaker strips: ASTM D226 No. 15 asphalt saturated roofing felt. - Cleaning agents: - Face Brick and CMU: ProSoCo, Inc., "Sure Klean New Masonry Cleaners." - ACMU: ProSoCo, Inc., "Sure Klean Burnished Custom Masonry Cleaner." - Expansion/Control joint sealants: Polyurethane-based, elastomeric joint sealant complying with ASTM C920 and Section 07900 requirements. Color matched to adjacent surfaces. 3.1 Installation A. Preparation - Wet absorbent face brick masonry units requiring wetting, in accordance with BIA recommendations. - Lay concrete masonry units dry. - Establish, lines, levels and coursing. Ensure ties, anchors and flashing are correctly installed - Mix mortar cementitious materials and aggregate in a mechanical mixer. Add water in amount to provide satisfactory workable consistency of mortar. Retemper mortar as required within two hours of mixing to replace water lost be evaporation. Discard mortar after two and one-half hours of initial mixing. Do not use mortar after it has started to set. B. Installation - General: - Build walls and other masonry construction to the full thickness shown. Build single wythe walls to the actual thickness of the masonry units, using units of nominal thickness shown. - Cut masonry units using motor-driven masonry saws to provide clean, sharp edges. Cut units to fit adjoining work neatly. Provide 100% solid units where cores would be exposed. - Cold weather construction, hot weather construction, and masonry construction tolerances: Comply with unit masonry standard ACI 530.1/ASCE 6/TMS 602 requirements. C. Laying Masonry - Layout walls in advance to ensure accurate spacing of surface bond patterns, with uniform joint widths, and to properly locate openings, movement type joints, returns and offsets. Do not use less than half-size joints at corners, jams and other locations. - Lay up walls plumb and true to comply with ACI 530.1 tolerances. Provide square corners and angles, except as otherwise indicated, with courses level, accurately spaced and coordinated with other work. - Pattern bond: Running bond. Do not use units with less than 4" of horizontal face dimensions at corners or jams. - Lay hollow CMU/ACMU with full mortar coverage on horizontal and vertical face shells. Bed CMU webs in mortar in starting courses. Maintain uniform 3/8" joint widths. - Lay face brick and solid CMU/ACMU with completely filled bed and head joints. Do not slush head joints. Maintain uniform 3/8" joint widths. - Compress and cut joints flush for masonry walls below grade or covered by other materials. - Tool joints in all exposed masonry work to a concave joint. - Provide interlocking masonry bond in each course at corners and intersecting walls. - As the work progresses, build in masonry accessories and related items. Fill in solidly with masonry around built-in items. - Bed hollow metal frame anchors in mortar and fill space between hollow metal frames and masonry solid with fine mortar grout. - Provide solid masonry bearing for all lintels, beams, joists, plates and load-bearing members. - Take particular care to embed all conduits and pipes within concrete masonry without fracturing exposed shells and to fit units around switch, receptacle and other boxes set in walls. Where electric conduit, outlets, switch boxes and similar items occur, grind and cut units before building in services. - Install anchors, plates and related work built into masonry work. - Install reinforcing steel and concrete fill where indicated. Comply with drawing details. - Horizontal joint reinforcing: Provide continuous joint reinforcing at all concrete masonry walls as follows: - In every second block course, 16" on center vertically, full height of wall and every block course where shown on the drawings. - Lap reinforcement a full width at the corners and at intersections or use special fabricated sections. - Fully embed side rods in mortar. - Anchoring masonry work: Provide anchoring devices of the type indicated or required. - Provide vertical expansion, control and isolation joints in masonry where indicated. - When not indicated, at maximum 30'-0" on center. - Locate control joints at points of natural weakness in masonry and acceptable to Architect. - Joint sealant color shall match masonry materials sealed. - Lintels: Install loose steel lintels furnished under structural steel work where shown. Set lintels in full bed of mortar. - Flashing and weeps: - Install concealed through wall masonry flashing at all wall sills, masonry openings in exterior walls with masonry above head, over all horizontal steel members built into masonry and elsewhere as indicated. Provide "drainage wall system" masonry construction. - Provide end dams and positive slope to drain. Extend flashing vertically at least 8" and built into or anchor to back-up with a termination bar for a complete watertight installation. - Flexible Membrane Flashing: - Install membrane flashing in accordance with manufacturer's installation instructions. - Fully adhere flashing to substrate. - Lap flashing joints a minimum of 6", seal and roll with a hand roller. - Trim bottom edge 1/4" back from exposed face of masonry. - Seal edges, seams, cuts and penetrations with manufacturer's recommended mastic. - Install weeps in head joints of final course of exterior masonry wythe above flashing. Space weeps maximum of 24" on center horizontally and located to avoid door openings. Install weeps at head joints with outside face of weep material held 1/8" from the finish face of masonry unit. - Install compressible joint material at lintels and horizontal steel members. Build in joint fillers and seal with elastomeric joint sealant. D. Masonry Veneer Walls: - Metal framed walls: Tie exterior masonry veneer wythe to back-up wall with individual metal ties screwed to metal stud framing. - Space ties 16" on center vertically and horizontally. - Maintain veneer wall cavity free of mortar droppings during masonry installation. E. Parging: - Dampen masonry walls prior to parging. - Scarify each parging coat to ensure full bond to subsequent coat. - Parge masonry walls in two uniform coats of mortar to a total thickness of 3/4 inch (19mm). - Steel trowel surface smooth abs flat with a maximum surface variation of 1/8 inch per foot (1mm/meter). F. Architectural Concrete Masonry Units: Install ACMU in accordance with the manufacturer's installation instructions and the following: - Draw ACMU from more than one pallet at a time during installation. G. Reinforced Concrete Masonry - Reinforce and fill CMU/ACMU wall and column masonry where indicated. Fill all cores solid with concrete fill. Comply with NCMA TEK Bulletins 3-2, 3-3A and 14-2 recommendations. - Comply with drawing details for reinforcing steel size and spacing. - Install bond beams where indicated. Reinforce and fill units solid with concrete fill. Comply with drawing details for reinforcing steel size and spacing. H. Repair, Pointing and Cleaning - In process cleaning: Wipe off excess mortar as the work progresses. Dry brush with bristle brushes exposed masonry at the end of each day's work. Remove mortar spatters and joint ridges. - Clean all exposed masonry. Cleaning agents subject to Architect's approval. Before applying any cleaning agent to the entire wall, clean a sample wall area of approximately 20 square feet in a location acceptable to the Architect. Do not proceed with final cleaning until the sample area has been allowed to dry a minimum of 3 days and the test area cleaning approved. Protect all windows, doors, louvers, metal lintels and other corrodible parts. Damaged materials and work replaced at Contractor's expense. - Dry clean exposed surfaces to remove large particles of mortar using hardwood wood paddles and scrapers. Metal tools not acceptable. - Presoak exposed masonry surfaces by saturating with water and flush off loose mortar and dirt
--	--	--

[illegible]

SECTION 07512 - ROOFING SYSTEM REPAIR

1.1 General: When penetration of the existing roofing system is required to accommodate new construction, perform necessary roofing system repair.

- A. Coordination: Before starting work, verify with the Tenant's Construction Manager and the Owner the following:
- Existing roof system materials and installation methods.
 - Repair work responsibilities and warranty requirements. To maintain original warranty, where provided use original roof contractor.
- B. Qualifications: Repair work shall be performed only by an experienced roofing installer approved or licensed by the existing roofing system materials manufacturer; with not less than five years of successful experience installing and repairing roofing systems similar to this projects existing roofing system.

2.1 Materials:

- A. Provide and install only materials approved and recommended by the roofing manufacturer for repairing the existing roofing system.

3.1 Installation:

- A. Preparation: Inspect roof surface conditions with roof manufacturer's representative to verify extent and location of any other repairs required to ensure a watertight roofing system upon completion of the repair work.
- B. Make necessary repairs. Match existing roof slope, insulation materials and roofing membrane materials, except as otherwise approved by the existing roofing system manufacturer to accommodate new construction and repair work.
- C. Install curb flashing furnished by mechanical and electrical trades for new roof top equipment.

SECTION 07540 - THERMOPLASTIC MEMBRANE (PVC) ROOFING

1.1 General: Provide the thermoplastic membrane (PVC) roofing system as shown and specified.

- A. Standards: Materials and construction shall conform to following:
- ASTM D5036 "Application of Adhered Poly(Vinyl Chloride) Sheet Roofing."
 - FM 1-29 Loss Prevention Data Adhered or Mechanically Attached Single Ply Membrane Roof Systems."
 - NRCA "Single-Ply Roofing Membrane."
 - UL "790 - Tests for Fire Resistance of Roof Covering Materials."

- B. Installer Qualifications: An experienced roofing installer approved by roofing system manufacturer and with not less than five years of successful experience installing membrane roofing systems similar to those required for this project.

- C. Deliver, store and handle roof system materials in accordance with manufacturer's recommendations to avoid damage and deterioration.
1. Comply with manufacturer's recommendations for handling and protection during installation.

- D. Install roofing work only when weather conditions are in compliance with manufacturer's specific environmental requirements and conditions will permit work to be performed in accordance with manufacturer's recommendations and warranty requirements.
- Protect adjacent materials and surfaces from damage and soiling during roofing system installation.
 - Provide special protection on completed roofing work.
 - Protect paving and structure walls adjacent to hoists before starting work.
 - Do not overload the building structure with storage of materials or installation equipment on the substrate decking.

E. Warranty

- Contractor and roof system installer shall jointly warrant roofing materials and installation for a period of two years from the date of Substantial Completion. Warranty shall include roofing membrane, flashing, roof insulation, roofing accessories and sheet metal work provided under Section 07600.
- Manufacturer's warranty: Submit executed copy of roofing system manufacturer's 15 year total system warranty, including labor and materials for the entire roof system. Including perimeter edge metal, Section 07600 Flashing & Sheet Metal

2.1 Materials

- A. Manufacturer: Duro-Last Roofing, Inc. (614) 370-5569, Mike Suman, www.duro-last.com
- Basis of Design Product Roofing System
 - Thermoplastic single ply membrane roofing system: DL Membrane (PVC) fully adhered, smooth surface, UL Class A fire-rated single ply membrane roofing system.
 - Thermoplastic fiber reinforced PVC membrane, not less than 40 mils (.040), complying with ASTM D4434 and membrane manufacturer's published physical properties.

- B. Comparable Alternate Roof Manufacturers:
- Versico Roofing Systems, (480) 528-6923, Jeff Kelly, jeff.kelly@versico.com
 - VersiFlex PVC Adhered System
 - Other comparable alternates can be considered when approved by Arch PM and Chipotle DM/CM.

- C. The roof covering design must resist a wind load of 100 mph, Exposure C and shall resist impact damage based on results of tests based on the results of tests conducted in accordance with ASTM D 3746, ASTM D 4272, CGSB 37-GP-52M or FM 4470
- Insulation cover board: Georgia-Pacific Corp. (800) 284-5347, internet www.gp.com, "Dens-Deck" nonstructural fiberglass-faced, silicone-treated gypsum core panels, 1/2" thickness.
 - Roof insulation: Rigid closed cell polycycanurate boards approved by the membrane manufacturer; complying with ASTM C1289, Type II, minimum 20 psi compressive strength, aged R-value equal 5.6 per inch of thickness.
 - Provide a double layer installation. Minimum total R-value as indicated on plans.
 - Specified perimeter edge metal shall be compliant with International Building Code ANSI / SPRI ES-1, ER2 testing requirements.
 - Flashing: Roof system manufacturer's standard sheet flashing of same material, type, and color as sheet membrane. Specified perimeter edge metal will be compliant with International Building Code ANSI / SPRI ES-1, RE2 testing requirements.
 - Membrane Bonding Adhesive: Roof system manufacturer's standard membrane bonding adhesive.
 - Insulation and Cover Board Adhesive: Dow Chemical Company, (888) 868-1183, internet www.flexibeproducts.com, "INSTA-STIK Professional Roof Insulation Adhesive", a single component, moisture cured polyurethane adhesive.
 - Fasteners: Roof system manufacturer's standard fasteners for project conditions indicated.
 - Accessories: Roof system manufacturer's recommended pourable sealers, preformed penetration flashing, preformed corner flashing, seam caulk, termination bars and other accessories required for substrate surfaces and installation conditions indicated.
 - Traffic walkways: Duro-Last Roof Track II walkway pads.3.1 Installation

3.1 Installation

- A. Preparation:
- Clean substrate surfaces of debris and other substances detrimental to roofing installation.
 - Correct unsatisfactory conditions before starting roofing. Roof deck surface conditions shall comply with manufacturer's requirements and be acceptable to the roofing system installer.
- B. Installation:
- General: Provide roofing system materials and installation complying with roofing system manufacturer's instructions and governing codes and regulations.
 - Mix and apply roof insulation and cover board adhesive in strict accordance with the adhesive manufacturer's installation instructions. Dispense adhesive at manufacturer's recommended application rate using approved dispensing equipment.
 - Roof insulation
 - Extend insulation full thickness over entire surface to be insulated. Cut and fit around obstructions; fill all voids with insulation. Provide saddles and tapered edges as required to provide positive proper drainage.
 - Install and secure in place with insulation adhesive, a double layer of insulation units of the required thickness. Run long joints of insulation in continuous straight lines, perpendicular to roof slope, with end joints staggered between rows. Stagger joints of each layer of insulation. Butt edges to moderate contact. Limit joints between adjacent units to maximum 1/4".
 - Insulation cover board: Install and secure in place with insulation adhesive a single layer of insulation cover board on installed roof insulation. Secure cover board in accordance with membrane manufacturer's recommendations. Stagger joints with joints of roof insulation.

- Thermoplastic membrane: Comply with membrane manufacturer's instructions and recommendations for handling and installing single ply membrane roofing.
 - Unroll and position roofing sheet membrane without stretching. Align top sheet with pr-marked lines on bottom sheet. Allow membrane to "relax" for at least 30 minutes before adhering, splicing and flashing.
 - Adhere membrane to insulation cover board with bonding adhesive. Broom bonded membrane to achieve maximum contact.
 - Join membrane seams using approved heat welding equipment. Check all splices for voids and repair voids with heat gun and roller.
 - When required, mechanically fasten membrane at roof perimeter, curb flashing and similar penetrations in accordance with manufacturer's installation instructions.
 - Flash and make weathertight all equipment curbs, pipes, conduits, drains and other penetrations or projections through sheet roofing using roofing system manufacturer's recommended flashing materials, accessories and procedures.
- Install roof accessories and traffic walkways in accordance with manufacturer's instructions.
- Install sheet metal work furnished under section 07600.

SECTION 07600 - FLASHING AND SHEET METAL

General:

- A. Standards: Materials and construction shall conform to following:
- SMACNA "Architectural sheet Metal Manual- 1993."
 - Installation: Performed under Section 07540 work.

1.1 Pre-manufactured perimeter edge metal and accessories

- Manufacturer: Duro-Last Roofing / Exceptional Metals, Inc, (800) 248-0280, Jason Dark, www.Duro-Last.com
- Duro-Last / Exceptional Metals Snap Coping made of 24-gauge galvalume, cover provided with Kynar architectural finish providing a 35 year finish warranty. Meets ANSI/SPRI ES-1 2003 method RE-2 testing requirements. (Color - Refer to Exterior Elevations)
- B. Duro-Last / Exceptional Metals Vinyl backed scupper. Scupper profile & size indicated Fig 1-20.

1.2 General: Miscellaneous sheet metal

- A. Standards: Materials and construction shall conform to following:
- SMACNA "Architectural sheet Metal Manual- 1993."
 - Installation: Performed under Section 07540 work.

2.1 Materials:

- A. Galvanized steel: ASTM A653 commercial quality sheet steel with 0.2% copper, G90 hot-dip galvanized. Gage indicated.
- Scuppers: Minimum 16 gage.
 - Coping/Wall caps: Minimum 18 gage.
- B. Aluminum sheet: ASTM B209 alloy 3003, temper as required for forming and performance. Thickness indicated.
- Conductor Boxes: Minimum 0.040"thickness.
 - Downspouts: Minimum 0.025"thickness.
- C. Joint sealers: One-component silicone elastomeric joint sealant complying with ASTM C920. Color matched to sheet metal finish.
- D. Metal accessories: Provide sheet metal fasteners, clips, straps, anchoring devices and similar accessory units as required for installation of work, matching or compatible with material installed, non-corrosive, size and gage as required for performance and acceptable to the Architect.
- E. Fabrication: Shop fabricate sheet metal work to comply with profiles and sizes indicated and to comply with standard industry standards as shown by SMACNA in the "Architectural Sheet Metal Manual."
- Conductor boxes: SMACNA Chapter 1 - Roof Drainage Systems. Profile and size indicated Fig 1-25.
 - Scuppers: SMACNA Chapter 1 - Roof Drainage Systems. Profile and size indicated Fig 1-20.
 - Downspouts: SMACNA Chapter 1 - Roof Drainage Systems. Profile and size indicated. Installation Fig. 1-31 with strap hanger Fig. 1-35.
 - Formed coping/wall caps: SMACNA Chapter 3 - Copings. Design Fig 3-1. Profile and size indicated with Fig. 3-3 butt joints and concealed back-up plates. Install formed copings with continuous clad fasteners similar to Fig 3-1 at exposed face and screw fasteners with washers space maximum 24" on center at roof side.

3.1 Installation:

- A. Preparation: Coordinate sheet metal work with other work for the correct sequencing of items which make up the entire roof system of weatherproofing and rain drainage;
- B. Installation: Comply with SMACNA "Architectural Sheet Metal Manual" recommendations, drawing details and approved shop drawings for installation of the work.
- Anchor sheet metal items securely in place by methods indicated, providing for thermal expansion. Conceal fasteners and expansion provisions whenever possible. Install joint sealants where required.
 - Set units true to lines and levels indicated. Install work with sealed laps, joints and seams that will be permanently watertight and weatherproof. Bed flanges of sheet metal work in thick coat of roofing cement or sealant compatible with roofing membrane.
 - Separate sheet metal work from dissimilar metals and treated wood materials. Provide rosin-sized paper slip sheet over treated wood.
 - Fabricate, support and anchor conductor boxes and downspouts to withstand thermal expansion, stresses and full loading by ice or water without damage, deterioration or leakage.

SECTION 076113 - SHEET METAL WALL PANELS

1.1 General:

- A. Standards:
- Furnish all labor, material, tools, equipment and services for all preformed fascia and wall panels as indicated, in accord with provisions of Contract Documents.
 - Completely coordinate with work of all other trades.
 - Although such work is not specifically indicated, furnish and install all supplementary or miscellaneous items, appurtenances and devices incidental to or necessary for a sound, secure and complete installation.

B. Related work specified elsewhere:

- Structural steel: Section 05100
- Steel joists: Section 05200 or 05400
- Flashing and sheet metal: Section 07600

1.2 Quality Assurance:

- A. Applicable standards:
- SMACNA: "Architectural Sheet Metal Manual" Sheet Metal and Air Conditioning Contractors National Association, Inc.
 - AISC: "Steel Construction Manual" American Institute of Steel Construction.
 - AISI: "Cold Form Steel Design Manual: American Iron and Steel Institute.
 - ASTM A792-83-A250: Specifications for steel sheet, aluminum-zinc alloy coated (galvanized) by the hot dip process, general requirements (Galvalume).
- B. Manufacturer's qualifications:
- Manufacturer has a minimum of three years experience in manufacturing metal wall systems of this nature. Panels specified in this section shall be produced in a factory environment (not job site roll formed) with fixed base roll forming equipment assuring the highest level of quality control. A letter from the manufacturer certifying compliance will accompany the product material submittals.

1.3 Product Delivery, Storage and Handling

- A. Delivery: Deliver metal wall system to job site properly packaged to provide protection against transportation damage.
- B. Handling: Exercise extreme care in unloading, storing and erecting metal wall system to prevent bending, warping, twisting and surface damage.
- C. Storage: Store all materials and accessories above ground on well skidded platforms. Store under waterproof covering. Provide proper ventilation of metal wall system to prevent condensation build up between each panel or trim/ flashing component.

2.1 Materials

- A. Metal wall system profile:
- Shadow Rib: 3 inch deep x 16 inch width with 1 1/2 inch deep x 5 1/4 inch wide fluting
- B. Metal wall system style:
- Fluted face
 - Concealed fasteners
- C. Gauge: 24 gauge
- D. Substrate: Per Plans
- E. Texture: Smooth
- F. Finish: Premium thermoset silicone polyester (20 year warranty)
- G. Color: Polar White, to be painted per Exterior Elevations
- H. Acceptable Manufacturer: MBCI Houston, Texas (281) 445-8555.

3.1 Surface Conditions

A. Examination:

- Inspect installed work of other trades and verify that such work is complete to a point where this work may continue.
- Verify that installation may be made in accordance with approved shop drawings and manufacturer's instructions.

3.2 Installation

- A. Install metal wall system system so that it is weathertight, without waves, warps, buckles, fastening stresses or distortion.
- B. Install metal wall system in accordance with manufacturer's instructions and shop drawings.
- C. Provide concealed anchors at all panel attachment locations.
- D. Install panels plumb, level and straight with seams parallel, conforming to design as indicated.

3.3 Cleaning, Protection

- A. Dispose of excess materials and remove debris from site.
- B. Clean work in accordance with manufacturer's recommendations.
- C. Protect work against damage until final acceptance. Replace or repair to the satisfaction of the architect and work that becomes damaged prior to final acceptance.
- D. Touch up minor scratches and abrasions.

3.4 Field Painting

- A. Refer to section 09900 on G017
- B. Follow manufacturer's technical bulletin for Precoated Signature 200 MBCI wall panels.

Section 07900 – JOINT SEALERS

1.1 General: Provide joint sealers as shown and specified.

- A. Standards: Comply with ASTM C 920 requirements.

- B. Application: Performed by skilled, experienced joint sealer applicators.

2.1 Materials:

- A. Poly urethane sealants:
- Tremco Commercial Sealants (800) 321-7906, internet www.tremcosealants.com,
 - "Dymonic FC" One component, fast skinning, Low Modulus Polyurethane.
 - "Dymeric 240 FC" Multi Component, gun grade, chemically curing, tintable fast setting polyurethane sealant.
 - Sonneborn, (724) 756-9582, internet www.sonneborn.com
 - Color pack for polyurethane multi component, gun grade chemically curing sealant.
- B. Silicone Sealants:
- General Electric Silicones, (800) 295-2392, internet www.gesilicones.com
 - "SCS1700 Sanitary – Mold/Mildew Resistant Silicone", one component 100% silicone, fungicidal based sealant.
 - "SCS2700 Silpruf Silicone" one component medium modulus, natural cure silicone all purpose sealant.
 - "Silglaze II SCS2800- Glazing Sealant" one component, 100% silicone based sealer.
 - "GE Paintable Silicone" one component paintable silicone.
 - "SCS1009 Silicone Sealant" one-component acetoxy silicone for general purpose sealing and bonding
 - Dow Corning Silicones, (989)496-4000, www.dowcorning.com
 - "Dow 795" – one component, medium modulus, natural cure silicone.
- C. Firestopping Sealants: 3M Fire Protection Products, (800) 328-1687, internet www.3M.com/firstop
- "3M Fire Barrier CP 25WB+ Caulk" or approved equal
- D. Joint backing: Non-absorptive, non-staining compressible, non-gassing, polyethylene foam backer rod compatible with joint sealants.

3.1 Installation:

- A. Preparation: Clean and prepare joints prior to installing sealers:
- Wipe shipping oils from surfaces to be sealed. Remove protective films and/or install joint backer rod if joint is larger than 1/4" in width.
- B. Installation: Install joint sealant materials in strict accordance with manufacturer's installation instructions.
- Apply sealants in a uniform, continuous bead without gaps or air pockets. Hand tool and finish all joints so that a smooth, small, lip free uniform line is created along the substrate being shot. Remove any excess materials from tooled edges and ends of joint.
 - Install joint sealants to a depth no more than 1/2 the width of the joint.
 - Install sealants by proven techniques that result in sealants directly contacting and fully wetting joint substrates, completely filling recesses provided for each joint configuration, and providing uniform, cross-sectional shapes and depths relative to joint widths which allow optimum sealant movement capability.
 - Immediately, after sealant application, and prior to time skinning or curing begins, tool sealants to form smooth, uniform beads of configuration indicated to eliminate air pockets, and to ensure contact and adhesion of sealant with sides of joint. Remove excess sealants from surfaces adjacent to joint. Do not use tooling agents which discolor sealants or adjacent surfaces or are not approved by sealant manufacturer.
 - Clean off excess sealants or sealant smears adjacent to joints as work progresses by methods and with cleaning materials approved by manufacturers of joint sealers and of products in which joints occur.

4.1 Sealant Schedule:

- A. Kitchen Area:
- Provide a continuous bead of white GE SCS1700 silicone at the following locations:
 - Ceiling grid to FRP wall panels
 - Base of FRP wall panels to T.O. specified base material.
 - Walk in cooler walls to FRP wall panels.
 - Stainless closure pieces at cooler walls to FRP wall panels.
 - FRP/stainless corner guards to FRP wall panels.
 - Ceiling tile pipe penetrations.
 - Wall pipe penetrations and/or escutcheons perimeters. (water & gas lines).
 - Mop sink stainless surround perimeter to walls.
 - FRP closure panel, at top of cooler, to cooler walls.
 - FRP wall panels to hollow metal door frames.
 - Coke line bundle to PVC cap.
 - FRP inside corner pieces to FRP wall panels. Both sides of corner piece.
 - Battery backup cover panel to FRP.
 - Faucet's to FRP wall panels.
 - FRP wall panels to quarry tile cove base.
 - FRP to aluminum plate at walk thru.
 - Menu board light bracket to ceiling.
 - Mop sink base at quarry tile.
 - All sinks (multi-compartment, hand, mop and prep) to FRP/tile walls.
 - Paper towel dispensers & soap dispensers to FRP/tile walls.

- Provide a continuous bead of aluminum GE SCS1009 silicone at the following locations:
 - Stainless closer pieces, at sides of cooler walls - to cooler walls.
 - Stainless or aluminum plate closure pieces to diamond plate at cooler walls.
 - Diamond plate panel seam joints.
 - Diamond plate perimeter to cooler walls.
 - Base of diamond plate to quarry tile cove base.
 - Stainless closure panel, at top of cooler walls, to cooler walls.
 - Top of quarry tile cove base to cooler walls at inside of cooler.
 - Cooler wall/diamond plate penetrations.
 - Cooler door hinges and handles to diamond plate. DO NOT caulk door locking unit.
 - Stainless mop surround to stainless corners on mop sink.
 - Base of stainless corner pieces to schluter strip at base.
 - Exit door threshold perimeters. To frame and floor, interior and exterior.

- Provide a continuous bead of dark gray GE SCS2000 silicone at the following locations:
 - Base of hollow metal door jambs to quarry tile floor.

B. Managers Office:

- Provide a continuous bead of white GE SCS1700 silicone at the following locations:
 - Ceiling grid to FRP wall panels.
 - Perimeter of manager's desk to FRP wall panels.
 - Hollow metal door frame to FRP wall panels.
 - Top and ends of coat hanger bracket to FRP walls.
 - Base of FRP wall panels to quarry tile base.
 - Ceiling tile wire/pipe penetrations.
 - FRP inside corners to FRP wall panels. Both sides of corner piece.
 - Base of FRP wall panels to quarry tile.

- Provide a continuous bead of black or light bronze (use color of safe) GE SCS2000 silicone at the following locations:
 - Base of safe to floor.

C. Cooking Area:

- Provide a continuous bead of white GE SCS1700 silicone at the following locations:
 - Top of wall tile to sheetrock ceiling.
 - Ceiling diffusers perimeters to sheetrock ceiling.
 - Ceiling pipe penetrations.
 - Wall tile to aluminum walk thru surround.
 - Tile wall penetrations/escutcheons perimeters.
 - FRP wall panels to sheetrock ceilings.
 - FRP wall panels to aluminum end wall plates.
 - FRP inside corners to FRP wall panels. Both sides of corner piece.
 - Sink to white wall tile.
 - Paper towel dispenser/soap dispenser to white tile.
 - POS/Serving counter to wall tile.
 - Stainless shelf behind grill to wall tile.
 - Faucets to ceramic wall tile.

- Provide a continuous bead of aluminum GE SCS1009 silicone at the following locations:
 - Joint between hood and closure skirt.
 - Joint between hood support and hood. Both sides.
 - Connection joint between stainless shelf behind grill.
 - Hood to tile walls & sheetrock ceiling.
 - Hood gusset to wall tile on both sides.
 - Sink to bronze wall tile.
 - Paper towel dispenser/soap dispenser to bronze tile.
 - DML counter to bronze tile.

- Provide a continuous bead of dark gray GE SCS2000 at the following locations:
 - Base of equipment to concrete curbs/quarry tile.

- Provide a continuous bead of bronze GE SCS2097 at the following locations:
 - Ceramic tile inside corners.
 - Ceramic tile to aluminum end wall plates.

D. Restrooms:

- Provide a continuous bead of white GE SCS1700 silicone at the following locations:
 - Top of FRP to sheetrock ceiling or top of FRP trim to sheetrock wall.
 - Perimeter of toilets/urinals to floor or FRP.
 - Perimeter of mirror to FRP.
 - Sink to wall.
 - Perimeter of paper towel/garbage unit to wall.
 - Toilet paper/napkin disposals units to walls.
 - Stainless shelf to wall.
 - Wall penetrations under sink and or escutcheons to perimeters.
 - Hollow metal door frames to FRP.
 - Base of FRP wall panels to top of wall base.
 - FRP inside corners to FRP wall panels.

- Provide a continuous bead of black GE SCS2000 silicone at the following locations:
 - Base of black rubber wall base to floor.

- Provide a continuous bead of dark gray GE SCS2000 silicone at the following locations:
 - Base of hollow metal door frames to floor.

E. Dining area:

- Provide a continuous bead of white GE SCS1700 silicone at the following locations:
 - Wall tile to sheetrock walls.
 - Perimeter of aluminum storefront/windows/entrances to sheetrock walls.
 - Wainscot wall panels (Stonewood or other) to painted walls.
 - Diffuser/louvers perimeters to sheetrock walls.
 - Hollow metal door frames to painted walls - if needed.
 - Frame of service line counter to tile (joint to be caulked behind front face panels of counter).
 - Wall tile at serving line wall to POS counter.

- Provide a continuous bead of black GE SCS2000 silicone at the following locations:
 - Base of black rubber to floor (concrete or quarry tile) and gyp. bd. wall.
 - Wainscot (Stonewood or other) wall panels to sill of aluminum storefront/ windows.
 - Vertical joints of wainscot (Stonewood or other) wall panels to frames/painted walls/tile (ONLY if joint is uneven or plywood is showing).
 - Stonewood panels at serve line.

- Provide a continuous bead of aluminum GE SCS1009 silicone at the following locations:
 - Base of garbage surround to floor.

- Provide a continuous bead of Dow 795 silicone at the following locations:
 - Sill of aluminum storefronts to concrete or tile floor. Color to be determined per store to match storefront (Charcoal/Anodized Aluminum/Dark Bronze).

F. Utensil Counter:

- Provide a continuous bead of aluminum GE SCS1009 silicone at the following locations:
 - Stainless countertop to backplash. Horizontal & vertical joints.
 - Base of Coke machine to countertop.
 - Perimeter of tea drain tray to countertop.
 - Stainless backplash to white tile walls/painted walls.

- Provide a continuous bead of white GE SCS1700 silicone at the following locations:
 - Coke line bundle to PVC cap.

G. Fire Rated Walls:

- Provide a continuous bead of 3M 25WB+ at the following locations:
 - Wall/ceiling penetrations in rated walls.

H. Exterior Joints:

- Provide a continuous bead of Tremco Dymeric limestone urethane sealant at the following locations:
 - Sidewalk/concrete expansion joints.
- Provide a continuous bead of Dow 795 silicone or Tremco Dymeric 240 FC at the following locations:
 - Hollow metal door frames.
 - EIFS to abutting services.
 - Penetrations in EIFS.
 - Face brick or block control joints.
 - Perimeter of Aluminum Storefronts.

*Colors to be determined per store to match adjacent material colors. Verify with Chipotle Construction Manager and Architect.

 - For "Fog" EIFS use Tremco - "Natural White"
 - For "Knight's Armor" EIFS use Sonneborn - "Charcoal Gray" #276-U
 - For white brick use Tremco - "China White"
- Provide a continuous bead of aluminum GE SCS1009 silicone at the following location:
 - CO2 fill port stainless box.
 - Faucet for hose. (Please note: color to be determined per store. Verify with Chipotle Construction Manager and Architect).

CONSULTANT:



CLIENT:




CHIPOTLE MEXICAN GRILL, INC.
PO BOX 16266
COLUMBUS, OH 43216-2666
TELEPHONE: (614) 318-2482
INTERNET: WWW.CHIPOTLE.COM

COPYRIGHT 2024
THIS DRAWING IS AN INSTRUMENT OF SERVICE AND AS SUCH REMAINS THE PROPERTY OF CHIPOTLE MEXICAN GRILL, INC. PERMISSION FOR USE OF THIS DOCUMENT IS LIMITED AND CAN BE EXTENDED ONLY BY WRITTEN AGREEMENT WITH CHIPOTLE MEXICAN GRILL, INC.

PROJECT INFORMATION:

STORE NO.: 5037
HUNTLEY
12990 ROUTE 47, LOT 4B
HUNTLEY, IL 60142

SEAL:

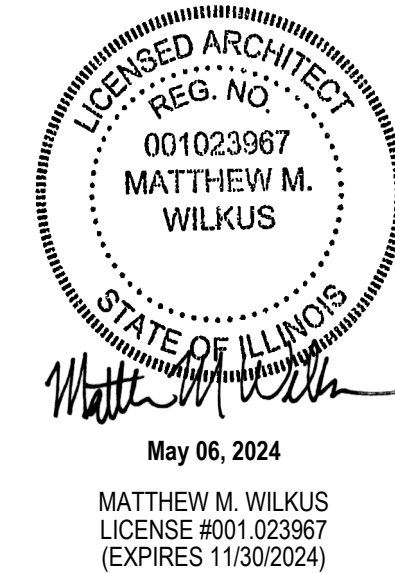

PROJECT NO. 2023-0175
DRAWN BY JSB_DVA
CHECKED BY DVA, NSG, KAM, MMW

ISSUE RECORD:
02/12/2024 PERMIT SUBMITTAL
03/15/2024 BID SET
05/03/2024 CONSTRUCTION SET

REVISIONS:

TITLE:

ARCHITECTURAL
SPECIFICATIONS

SHEET NUMBER:

G013

Division 8 - Doors and Windows	2.1 Submittals:	2.4 Glazing Systems:	2.12 Formed Metal Fabrications - Sheet Metal
SECTION 08110 - STEEL DOORS AND FRAMES 1.1 General: Tenant to provide steel doors and frames as shown and specified. A. Standards: Materials and construction shall conform to the following: - ANSI A250.8-2009 "Specifications for Standard Steel Doors and Frames." - ANSI A250.11-01 "Erection Instructions for Steel Frames." - SDI 122-99 "Installation for Standard Steel Doors and Frames." B. Manufacturer: A member of the Steel Door Institute (SDI). 2.1 Materials: A. Steel Doors: - Interior: Heavy-duty Level 2, physical performance B, Model 2 seamless construction, ASTM A1008, 18 gage cold-rolled steel face sheets, manufacturer's standard core. 2. Exterior: Extra heavy-duty Level 3, physical performance A, Model 2 seamless construction, ASTM A1008, 16 gage cold-rolled steel face sheets; tops and bottoms closed with flush galvanized steel caps, manufacturer's standard plastic foam insulating core. B. Steel Frames: ASTM A1008, 16 gage cold-rolled steel. - Provide combination buck, jamb and trim type frames for 1-3/4" thick doors, unless otherwise indicated. - Interior and exterior frames: Set-up welded type with mitered corners, reinforced, fully seam welded with exposed welds ground smooth. C. Door and frame fabrication: - Provide cutouts for mortised hardware, accurately located and made to fit hardware. Provide closer reinforcement for all doors with surface mounted door closers. - Punch frames and factory install rubber door silencers. - Provide minimum three anchors of suitable design for each jamb. - Provide floor clip on bottom of each jamb. Provide angle spreaders at bottom of each set-up frame. D. Shop painting: Clean and paint exposed surfaces of steel door and frame units. Apply one baked-on shop coat of rust-inhibitive prime paint in accordance with ANSI A250.10, unless doors and frames are used at the restrooms or as indicated on door hardware and finish schedule. Provide a uniformly finished surface ready to receive finish paint. 3.1 Installation: A. Install frames plumb, level, rigid, and in true alignment as recommended in ANSI A250.11. B. Install doors plumb and in true alignment and fastened to achieve the maximum operational effectiveness and appearance as recommended in SDI 122.	1.5 Submittals: A. Product Data: Include construction details, material descriptions, dimensions of individual components and profiles, hardware, finishes, and installation instructions for each type of aluminum frame storefront system and storefront entrance doors indicated. B. Shop Drawings: Include plans, elevations, sections, details, hardware, and attachments to work, operational clearances and installation details. C. Samples for Initial Selection: For units with factory-applied color finishes including samples of hardware and accessories involving color section. 1.6 Quality Assurance A. Installer Qualifications: An installer which has had successful experience with installation of the same or similar units required for the project and other projects of similar size and scope B. Manufacturer Qualifications: A manufacturer capable of providing aluminum framed storefront system that meet or exceed performance requirements indicated and of documenting this performance by inclusion of test reports, and calculations. C. Source Limitations: Obtain aluminum framed storefront system and storefront entrance doors through one source from a single manufacturer. D. Product Options: Drawings indicate size, profiles, and dimensional requirements of aluminum framed storefront system and are based on the specific system indicated. Do not modify size and dimensional requirements. - Do not modify intended aesthetic effects, as judged solely by Architect, except with Architect's approval. If modifications are proposed, submit comprehensive explanatory data to Architect for review. 1.7 Project Conditions: A. Field Measurements: Verify actual dimensions of a aluminum framed storefront openings by field measurements before fabrication and indicate field measurements on Shop Drawings. 1.8 Warranty A. Manufacturers Warranty: Submit, for Owner's acceptance, manufacturer's standard warranty. - Warranty Period: Two (2) years from Date of Substantial Completion of the project provided however that the Limited Warranty shall begin in no event later than six months from date of shipment by manufacturer. 2.1 Manufacturers: A. Manufacturer: Kawneer Company Inc., Contact: Doug Hess, Phone: 317-771-9265; email:doug.hess@arconic.com - Basis-of-Design Product Storefront Framing: - Trifab 601T (thermal) Storefront System 2" x 6" System Dimensions - Glass: Exterior (Center-Set) - Trifab 451T (thermal) Storefront System 2" x 4-1/2" System Dimensions - Glass: Exterior (Front-Set) - Basis-of-Design Product Storefront Entrances: - The door stile and rail face dimensions of the 500-Wide Stile entrance door will be as follows or as indicated on Drawings: Door: 500; Vertical Stile: 5"; Top Rail: 5"; Bottom Rail: 10" - Major portions of the door members to be 0.125" nominal in thickness and glazing molding to be 0.05" thick. - Glazing gaskets shall be either EPDM elastomeric extrusions or a thermoplastic elastomer. - Provide adjustable glass jacks to help center the glass in the door opening. - Basis-of-Design Product Feature Exterior Slat Wall: - Kawneer Tube #027881 (1" x 3"), capped at top and bottom - Alternate Exterior Slat Wall only when approved by Arch PM and Chipotle DM. - Architectural Fabrication - Alternate Storefront Systems only when approved by Arch PM and Chipotle DM. - YKK - YES 60 TU Storefront System - 2" x 6" nominal dimension; Thermal - YES 45 TU Storefront System - 2" x 4-1/2" nominal dimension; Thermal; Front-Set - Oldcastle - Series 6000XT Storefront System - 2" x 6" nominal dimension; Thermal - Series 3000 Thermal MultiPlane Storefront System - 2" x 4-1/2" nominal dimension; Thermal; Front-Set - US Aluminum - Series FT601 - 2" x 6" nominal dimension; Thermal - Series FT451 - 2" x 4-1/2" nominal dimension; Thermal; Front-Set - EFCO - Series 406 (T) Storefront System - 2" x 6-1/2" nominal dimension; Thermal - Series 403 (T) Storefront System - 2" x 4-1/2" nominal dimension; Thermal - Wausau - TU24650 Storefront System - 2" x 6-1/2" nominal dimension; Thermal - TU24000 Storefront System - 2" x 4-1/2" nominal dimension; Thermal	A. Glazing: As specified in Section 08800 - Glazing. B. Glazing Gaskets: Manufacturer's standard compression types; replaceable, extruded EPDM rubber. C. Spacers and Setting Blocks: Manufacturer's standard elastomeric type. D. Bond-Breaker Tape: Manufacturer's standard TFE-fluorocarbon or polyethylene material to which sealants will not develop adhesion. E. Glazing Sealants: For structural-sealant-glazed systems, as recommended by manufacturer for joint type, and as follows: - Structural Sealant: ASTM C 1184, single-component neutral-curing silicone formulation that is compatible with system components with which it comes in contact, specifically formulated and tested for use as structural sealant and approved by a structural-sealant manufacturer for use in aluminum-framed systems indicated. - Color: Black - Weatherseal Sealant: ASTM C 920 for Type S, Grade NS, Class 25, Uses NT, G, A, and O; single-component neutral-curing formulation that is compatible with structural sealant and other system components with which it comes in contact; recommended by structural-sealant, weatherseal-sealant, and aluminum-framed-system manufacturers for this use. - Color: Matching structural sealant. 2.5 Entrance Door Systems: A. Entrance Door Hardware: As specified in Section 08710 Door Hardware. 2.6 Accessory Materials: A. Joint Sealants: For installation at perimeter of aluminum-framed systems, as specified in section 07900 - Joint Sealers 2.7 Storefront Framing Fabrication: A. Framing Members, General: Fabricate components that, when assembled, have the following characteristics: - Profiles that are sharp, straight, and free of defects or deformations. - Accurately fit joints; make joints flush, hairline and weatherproof. - Means to drain water passing joints, condensation within framing members, and moisture migrating within the system to exterior. - Physical and thermal isolation of glazing from framing members. - Accommodations for thermal and mechanical movements of glazing and framing to maintain required glazing edge clearances. - Provisions for field replacement of glazing. - Fasteners, anchors, and connection devices that are concealed from view to greatest extent possible. B. Mechanically Glazed Framing Members: Fabricate for flush glazing without projecting stops. C. Structural-Sealant-Glazed Framing Members: Include accommodations for using temporary support device to retain glazing in place while structural sealant cures. D. Storefront Framing: Fabricate components for assembly using manufacturers standard installation instructions. E. After fabrication, clearly mark components to identify their locations in Project according to Shop Drawings. 2.8 Storefront Entrance Door Fabrication: A. Fabricate aluminum-framed glass entrance doors in sizes indicated. Include a complete system for assembling components and anchoring doors. B. Fabricate aluminum-framed glass doors that are reglazable without dismantling perimeter framing. - Door corner construction shall consist of mechanical clip fastening, SIGMA deep penetration plug welds and 1-1/8" long fillet welds inside and outside of all four corners. Glazing stops shall be hook-in type with EPDM glazing gaskets reinforced with non-stretchable cord. - Accurately fit and secure joints and corners. Make joints hairline in appearance. - Prepare components with internal reinforcement for door hardware. - Arrange fasteners and attachments to conceal from view. C. Weather Stripping: Provide weather stripping locked into extruded grooves in door panels or frames as indicated on manufactures drawings and details. 2.9 Aluminum Finishes: A. Finish designations prefixed by AA comply with the system established by the Aluminum Association for designating aluminum finishes. B. Factory Finishing: - Kawneer Permafluor (70% PVDF), AAMA 2605, Fluoropolymer Coating (Color: Charcoal or as noted on Drawings) - Finishing for alternate storefront specifications to be verified by Arch PM and Chipotle DM - YKK "Charcoal" UC99477, Superior Painted Finishes - All others to be verified with samples and submittals to Arch PM	A. Closures, Trim, and Fill Panels: - Form Closures from type and thickness of metal indicated. - Conceal fasteners when possible. - Drill and tap holes for securing to other surfaces. - Provide gaskets where indicated or needed for continuous seal at adjacent surfaces. - Miter or cope at corners and reinforce with bent metal plate. Form tight joints. 2.13 Materials A. General: Provide sheet metal without pitting, seam marks, roller marks, stains, discolorations, or other imperfections exposed to view on finished units. B. Galvanized Steel Sheet: ASTM A653/A653M, G90 [Z275] coating. 14 gage min. thick base material. C. Anchors, Clips, and Accessories: Use one of the following: - Stainless steel complying with ASTM A276/A276M, ASTM A480/A480M, or ASTM A666. - Steel complying with ASTM A36/A36M and hot-dipped galvanized to ASTM A153/A153M. - Steel complying with ASTM A36/A36M and hot-dipped galvanized to ASTM A123/A123M Coating Grade 35 - Interior locations: Carbon steel, zinc coated in accordance with ASTM B633 or ASTM F1941/F1941M, Class Fe/Zn S. - Exterior Locations or in contact with Stainless Steel: - Bolts: Stainless steel; ASTM F593, Group 1 (A1) - Nuts: Stainless steel; ASTM F594. - Structural Anchors: Provide anchors where work is indicated to comply with design loads. - Type: Provide chemical or torque controlled expansion anchors. - Capacity: When tested according to ASTM E488/E488M; four times the load imposed when installed in concrete. - Nonstructural Anchors: Provide powder-actuated fasteners where work is not indicated to comply wit design loads. Provide size and number required for load, installation, and as recommended by manufacturer, unless indicated otherwise. D. Fasteners, General: Same basic metal and alloy as formed metal sheet unless indicated otherwise. Do not use metals incompatible with the materials joined. E. Gaskets: As required to seal joints in decorative formed metal and remain airtight; as recommended in writing by decorative formed metal manufacturer. 2.14 Finishes A. Finishes, General: Comply with NAAMM AMP 5

CONSULTANT:	
 WILKUS ARCHITECTS	
CLIENT:	
CHIPOTLE MEXICAN GRILL, INC. PO BOX 162289 COLUMBUS, OH 43218-2566 TELEPHONE: (614) 316-2482 INTERNET: WWW.CHIPOTLE.COM	
COPYRIGHT 2024 THIS DRAWING IS AN INSTRUMENT OF SERVICE AND AS SUCH REMAINS THE PROPERTY OF CHIPOTLE MEXICAN GRILL, INC.. PERMISSION FOR USE OF THIS DOCUMENT IS LIMITED AND CAN BE EXTENDED ONLY BY WRITTEN AGREEMENT WITH CHIPOTLE MEXICAN GRILL, INC.	
PROJECT INFORMATION: 	
STORE NO.: 5037 HUNTLEY 12990 ROUTE 47, LOT 4B HUNTLEY, IL 60142	
SEAL:	
 May 06, 2024 MATTHEW M. WILKUS LICENSE #001.023967 (EXPIRES 11/30/2024)	
PROJECT NO. _____ 2023-0175	
DRAWN BY	JSB, DVA
CHECKED BY	DVA, NSG, KAM, MMW
ISSUE RECORD:	
02/12/2024	PERMIT SUBMITTAL
03/15/2024	BID SET
05/03/2024	CONSTRUCTION SET
REVISIONS:	
TITLE:	
ARCHITECTURAL SPECIFICATIONS	
SHEET NUMBER:	G014

2.2 In-Line Side Sliding Automatic Window and Air Curtain

- A. Standard Custom Side Sliding Windows – Arch PM to verify manufacturer with Tenant.

- Quikserv Custom Automatic Side Sliding Window (Model: SST-4035E-CHIPOTLE): 45 -1/2"W x 41-3/4"H window with 17-3/4" tall transom and (2) sidelights at 29 1/4"W x 41-3/4"H; Complete Unit Size 104"W x 59-1/2"H

1. Service Opening: 19"W x 29-3/4"H
2. Finish: Dark Bronze Anodized
3. Glass: 1" Clear Tempered unit + Low E (Solarban 60e) for fixed and moving panel, sidelights and transom
4. 'CHIPOTLE' package includes pre-wired air curtain with relay to sync operation with window.
a. Arch PM to verify if heated or ambient air curtain is required per Tenant assignment. Air Curtain mounts to transom.
i. Heated Air Curtain: Model: QSV102SEJ-040-BK
ii. Ambient Air Curtain: Model: QSK1025AA-BK
5. Refer to interior elevations (A700s) for direction of opening for ordering.

- ReadyAccess Automatic Side Sliding Window: 47 -1/2"W x 43-1/2"H window with 16" tall transom and (2) sidelights at 28 1/4"W x 59-1/2"H; Complete Unit Size 104"W x 59-1/2"H

1. Service Opening: 19"W x 35"H
2. Finish: Dark Bronze Anodized
3. Glass: 3/4" Clear Tempered unit + Low E (Solarban 70XL) for fixed & moving panel, sidelights and transom
4. Arch PM to verify if heated or ambient air curtain is required per Tenant assignment.
a. Heated Air Curtain: Model: AA300 (replaces transom)
b. Ambient Air Curtain: Model: AA100 (split transom)
5. Refer to exterior elevations (A300s) for direction of opening for ordering.

- B. Alternate California Code Option

1. ReadyAccess: Window 47-1/2" W x 35-3/4"H with double-split transom for air curtain and 10" and (2) sidelights at 28-1/4"W x 59-1/2"H; Complete Unit Size 104"W x 59-1/2"H
a. Service Opening: 15-1/4" W x 28"H, limited to meet CA code.
b. Ambient Air Curtain, AA100, and relay switch kit included with the West Coast Window package.

2. Quikserv Model: SS-4035-E-CHIPOTLE-CALI, same as above except as noted.
a. Service Opening: 28" W x 15-3/8"H, limited to meet CA code.
b. 'CHIPOTLE' package includes pre-wired ambient air curtain with relay to sync operation with window Model: QSK1025AA-BK. Air curtain mounts to transom.

- C. Alternate Impact-Resistant and Florida Product Approved Option, Miami Dade Horizontal Bi-Parting Impact Slider

1. Quikserv Model: BP-7241E-IP-CHIPOTLE, Complete Unit Size: 72"W x 41"H.
a. Service Opening: 29-1/2"W x 27"H
b. Rough Opening: 72-1/2"W x 41-1/2"H
c. Glass: Impact Resistant Glass
d. 'CHIPOTLE' package includes ambient air curtain
i. Ambient Air Curtain: Model: QSK1025AA-BK, Part Number: 9345.
ii. Do not mount directly to window, mount on wall above.
e. Miami-Dade NOA #18-0814.02

2.3 Electrical Requirements

- A. Quikserv Electrical Windows: 120V / 60 Hz, 20-amp branch circuit, single phase. Power supplied through base of window. Conforms to UL Standard 325 – Certified to CAN/CSA C22.2 NO. 247. Confirm with Electrical Drawings.

1. Heated Air Curtain for Custom Side Sliding Window (Model: SS-4035-E-CHIPOTLE)
a. Separate 230V circuit and Power Supply required for heated air curtain. Air curtain pre-wired through window frame with power supply routed to base of window. Confirm with Electrical Drawings.
2. Ambient Air Curtain for Custom Side Sliding Window (Model: SS-4035-E-CHIPOTLE) and Alternate California Code Option: Model: SS-4035-E-CHIPOTLE-CALI
a. Separate circuit not required. Window pre-wired to power and sync operation with air curtain.
3. Ambient Air Curtain for Alternate Impact-Resistant and Florida Product Approved Option (Model: BP-7241E-IP-CHIPOTLE):
a. Connect to main control board on window to power and synchronize operation with opening and closing of window.

- B. ReadyAccess Electrical Windows: 115V / 60 Hz, 15-amp dedicated circuit required. Run power to header on fixed panel side.

1. AA300 Heated Air Curtain
a. Separate 208V /60 Hz /40-amp single phase circuit required.
2. AA100 Ambient Air Curtain (Standard and CA window)
a. Separate 120V / 60Hz / 15-amp single phase circuit required. Run power to center of window above header.

3.1 Installation

- A. Install in accordance with manufacturer's instructions.
B. Install pass-thru windows plumb, level, square, true to line, and without warp or rack. Maintain dimensional tolerances and alignment with adjacent Work.
C. Install thermal isolation where components penetrate or disrupt building insulation. Pack fibrous insulation in shim spaces at perimeter of assembly to maintain continuity of thermal barrier.
D. Install pass-thru window components weathertight.
E. Anchor pass-thru windows securely in place to supports. Use attachment methods permitting adjustment for construction tolerances, irregularities, alignment, and expansion and contraction.
F. Separate aluminum from other metal surfaces with bituminous coatings or other means approved by Architect.
G. Coordinate installation of related sheet metal flashing as specified in Section 07 62 00 - Sheet Metal Flashing and Trim.
H. Install perimeter joint sealants as specified in Section 07 91 23 - Backer Rods.

SECTION 08710 - DOOR HARDWARE

- 1.1 General: Provide door hardware as shown and specified.

- A. Standards: Materials and installation shall conform to the following:
1. ANSI A117.1-2009 Accessible and Usable Buildings and Facilities.
2. ANSI/BHMA A156 Series Builders Hardware

- B. Quality Assurance:
1. Codes and standards: Provide hardware complying with local Building Code requirements and the Tenant's standards for keying and security systems.
2. Project scheduling: Performed by an Architectural Hardware Consultant (AHC).
3. Package each item of hardware and each lockset, complete with all screws, anchors, installation instructions and templates. Identify package indexing with corresponding item number of the hardware schedule.
4. After hardware schedule acceptance, provide necessary templates or physical hardware to required trades for cutting, reinforcing, or preparing their products to receive hardware. Furnish templates to metal door manufacturer's.

2.1 Materials:

- A. No substitutions allowed. Requirements for manufacturer, design, grade, function, finish, size and other distinctive qualities of each type of door hardware are indicated on the drawings.

- B. Review the keying system with the Tenant and provide the type required.

3.1 Installation

- A. Install each hardware item in strict accordance with manufacturer's installation instructions and recommendations. Securely fasten all attached parts. Fit faces of mortised parts snug and flush. Verify operating parts move freely and smoothly without binding or sticking, without excessive clearance.

- B. Set units level, plumb and true to line and location. Adjust and reinforce attachment substrate as required for proper installation and operation. Drill and countersink units that are not factory prepared for anchorage fasteners. Space fasteners and anchors in accordance with industry standards.

- C. Mount hardware units at heights indicated in DHI "Recommended Locations for Builders Hardware", unless otherwise required to comply with requirements of governing codes and regulations. Conform to ANSI A117.1 and ADAGG guidelines for accessibility.

1. Top Butts: 5 inches; top of butt from head of frame.
2. Middle Butts: 3'-2", centerline from finish floor.
3. Bottom Butts: 5 inches; finish floor to bottom of butt.
4. Locks: centerline from finish floor per hardware schedule.
5. Knobs: 3'-2", centerline from finish floor.
6. Pulls: centerline from finish floor per hardware schedule.
7. Pushes: centerline from finish floor per hardware schedule.

SECTION 08800 - GLAZING

- 1.1 General: Provide glass and glazing as shown and specified.

- A. Standards: Materials and installation shall conform to the following:
1. CPSC 16 CFR Part 1201 (1-91)"Safety Standard for Architectural Glazing Materials."
2. GANA "Glazing Manual - 1990."

B. Quality Assurance:

1. Codes and standards: Provide type of glass and glazing products that comply with ANSI Z97.1 and testing requirements of 16 CFR Part 1201 for category II materials. Comply with all applicable codes, standards and regulations that control safety glazing materials and installation.
2. System Performance: Provide glass and glazing that has been produced, fabricated and installed to withstand normal thermal movement, wind loading and, where applicable, impact loading, without failure including loss or breakage of glass, failure of glazing sealants or gaskets to remain watertight and airtight, deterioration of glass and glazing materials and other defects in the work.
3. Installation: Performed only by experienced glaziers.

C. Warranty:

1. Insulating glass: Five years from date of installation against defects that materially obstruct vision through the glass or affect thermal and physical integrity.

2.1 Materials:

- A. Glass:
1. Float Glass (FG): 1/4" thick clear float glass.
2. Tempered Glass (TG): 1/4" and 1/2" thick clear, tempered safety glass, free-of-tong marks.
3. Insulating Glass (IGL): 1" thick clear, low-e tempered sealed glass; 1/4" thick interior and exterior glass lites with 1/2" aluminum desiccated dual sealed air space; with the following characteristics:
a. Low-emissivity coating on #2 surface.
b. Visible Light Transmittance: 64% - 70%
c. Solar Light Reflectance: 32%-34%
d. Solar Energy Transmittance: 30%-34%
e. Solar Energy Reflectance-Outdoors: 30%-34%
f. U-Value - Winter Night: 0.29
g. U-value - Summer days: 0.28
h. Solar Heat gain Coefficient: 0.25-0.39
i. Shading Coefficient: 0.43-0.45
j. Manufacturers/Products:
i. AGC/Comfort Ti-AC40, or similar to meet code
ii. Sun Guard/SN-68, or similar to meet code
iii. PPG/Solarban 60, or similar to meet code
iv. Viracore/VEL-2M, or similar to meet code
4. Spandrel Glass (SG) 1/4" thick, Spandrel Ceramic Glass, (Color: Gray/Black or as noted on drawings) by Old Castle Window Envelope (419) 666-2000, Contact: Doug Dewar
5. Frosted Window Film, 3M Dusted Crystal Translucent Window Film. Apply on the interior side of glazing.

- B. Glazing Materials:
1. Glazing Sealants: Provide elastomeric glazing sealants suitable for applications indicated; compatible with one another and with other materials they will contact, complying with ASTM C920.
2. Glazing Tape: Provide preformed, non-staining and non-migrating elastomeric tape, as recommended by tape and glass manufacturers for application indicated, complying with ASTM C 1281.
3. Glazing gaskets: Provide manufacturer's standard snap-on aluminum stops and neoprene, vinyl or EPDM glazing gaskets.
4. Provide setting blocks, spacers and edge blocks of material, size, and shape complying with referenced glazing standard, and compatible with surfaces contacted in installation.

- C. Fabrication: Factory fabricate and size all glass.

3.1 Installation

- A. Preparation:
1. Field verify measurements and conditions of installation.
2. Examine all details. Provide proper fitting to details indicated.
3. Glazing channel dimensions shown are intended to provide for necessary bite on glass, minimum edge clearance and adequate glazing materials thickness, with reasonable tolerances. Adjust as required by job conditions at time of installation.
B. Install glass and glazing in accordance with the GANA "Glazing Manual" and glass manufacturer's recommendations.
1. Install insulating glass units to comply with recommendations by Sealed Insulating Glass Manufacturers Association (SIGMA).
C. Install setting blocks of proper size at quarter points of sill rabbet. Provide spacers as required.
D. Install glazing sealants, tapes and gaskets in accordance with manufacturer's recommendations. Set glass without springing and install securely to prevent rattling or breakage.
E. Protect glass from breakage during remaining construction. Do not remove non-permanent labels until final acceptance.

DIVISION 9 -- FINISHES

SECTION 09260 - GYPSUM BOARD SYSTEMS

- 1.1 General: Provide gypsum board systems as shown and specified.

- A. Standards: Materials and installation shall conform to the following:
1. GA 214-90 "Levels of Gypsum Board Finish."
2. GA-216 "Specifications for Application and Finishing of Gypsum Board."
3. USG "SA923 Drywall/Steel Framed Systems."

2.1 Materials:

- A. Manufacturer: United States Gypsum Co. (USG), (800) 874-4968, internet www.usg.com.

B. Metal framing: Comply with ASTM C 754 and ASTM C 645 for materials and sizes.

1. Partition metal framing:
a. Studs: Galvanized steel, C-shaped, sizes indicated, 20 gage "ST20"
b. Runners: Match studs, type recommended by stud manufacturer for floor and ceiling support of studs. Provide flexible ceiling runners for full height metal stud framed partitions continuous from floor to underside of structural members or deck above.
C. Ceiling and Soffit metal framing/suspension systems:
1. Small areas: Metal stud framing of appropriate size and gage for spans indicated.
2. Large areas: Furring channel "Grillage" or "Direct Suspension System" designed for concealed support of gypsum board ceilings, of proper type for use indicated.
3. Furring members: 20 gage, galvanized steel screw type, hat-shaped furring.

- D. Gypsum board panels: USG "Sheetrock" complying with ASTM C1396, tapered edge face panels, 48" wide, in maximum lengths available to minimize end joint conditions, 5/8" thick.
1. General use panels: Sheetrock Regular panels.
2. Fire rated panels: Sheetrock Firecode Core panels.
3. Water-resistant: panels: Sheetrock HUMITEK panels.

- E. Cement board: USG DUROCK Cement Board, 5/8" thick x manufacturer's standard width, complying with ANSI A118.9, and in maximum lengths available to minimize end-to-end butt joints.

- F. Fasteners: USG Type "S" bugle head screws for metal framing, USG Type "W" bugle head screws for wood framing, manufacturer's recommended length for panel thickness indicated.

- G. Trim: Galvanized steel with knurled and perforated flanges. USG Dur-A-Bead corner bead, No. 2008 casing bead metal trim, No. 093 Control Joint.

- H. Joint treatment: USG Joint Treatment System, utilizing "Sheetrock Brand Joint Tape", and "Sheetrock Brand Setting-Type (DURABOND)" compound for tape bedding and topping.

- I. Adhesives: USG "Sheetrock Brand Setting-Type (DURABOND) 210 or 90" compound for tape bedding and topping.

- J. Acoustical sealant: USG Sheetrock Acoustical Sealant, water-base type, gunnable sealant for sealing sound-rated gypsum board systems.

- K. Sound attenuation insulation: USG Thermafiber unfaced 3-1/2" thick, mineral fiber insulating batts/blankets; standard lengths and widths required to coordinate with spaces insulated.

3.1 Installation

- A. Install metal wall and partition framing and ceiling suspension/ support systems in accordance with USG Bulletin SA 923 and complying with ASTM C754.
1. Ceiling suspension/ support systems: Metal furring system/direct suspension or steel stud framing system.
2. Wall and partition framing:
a. Install steel studs per schedule or at spacing indicated with bottom and top runner tracks anchored to substrates. Provide flexible ceiling runner tracks at full height partitions.
b. Terminate partition stud system 4" above ceilings, except where indicated to be extended to structural support or roof deck above. Brace tops of partition framing to structure or roof deck at maximum 4'-0" on center spacing.
c. Frame openings more than 2'-0" wide with two 20 gage studs at each jamb.
d. Coordinate the installation of supplementary blocking and nailers, provided under Section 06100 work, to support shelving, millwork, toilet accessories, and similar work that cannot be adequately supported by gypsum board alone.
B. Application and Finishing: Install and finish gypsum board to comply with ASTM C 840 and Gypsum Association GA 216 "Recommended Specifications for the Application and Finishing of Gypsum Board."
1. Screw fasten all gypsum board panels.
2. Metal Trim: Install metal corner beads at external corners of gypsum board work and metal trim wherever edge of gypsum board would be exposed. Use longest practical lengths.
3. Control Joints: Locate and install control joints in accordance with USG Bulletin SA923 "Good Design Practice" recommendations.

- C. Acoustical Treatment:
1. Where sound-attenuation insulation is indicated, seal gypsum board construction at perimeters, control joints, junction boxes, openings and penetrations with a continuous bead of acoustical sealant including a bead at both faces of partitions.
2. Install sound attenuation insulation at scheduled partitions and ceilings. Install insulation in single layer of required thickness. Extend full thickness over entire area to be insulated. Cut and fit tight around obstructions. Fill all voids.
3. At openings and cutouts, fill open spaces between edges of gypsum board and fixtures, cabinets, ducts, and other flush or penetrating items, with continuous bead of acoustical sealant.
4. Seal sides and backs of electrical boxes to completely close up openings and joints with a bead of acoustical treatment.

D. Finishing:

1. Comply with manufacturer's instructions for mixing, handling, and application of materials. Apply treatment at joints both directions, at flanges of trim accessories, penetrations of gypsum board (electrical boxes, piping, and similar work), fastener heads, surface defects, and elsewhere as indicated. Apply in manner that will result in each of these items being concealed when applied decoration has been completed.
2. Apply joint tape at joints between gypsum boards, except where trim accessories are indicated.
3. Interior Exposed Gypsum Board Finish: Level 5 Finish.
a. Locations: Typical for all walls and ceilings, unless otherwise indicated
b. Finish interior gypsum board by applying the following joint compounds in four coats (not including prefill of openings in base), and sand between coats and after last coat:
c. Embedding and First Coat: Setting-type joint or taping compound.
d. Fill (Second) Coat: Setting-type topping compound.
e. Fill (Third) Coat: Setting-type topping compound.
f. Finish (Fourth) Coat: Skim coat entire surface.
4. Interior Concealed Gypsum Board: Level 3 Partial Finishing.
a. Finish concealed gypsum board construction that requires finishing same as exposed gypsum board construction, except the third coat and sanding can be omitted.

- E. Cement Board: Install cement board as a 16" high base at all kitchen and kitchen cook line wall types as indicated on drawings.

SECTION 092816 - GLASS-MAT FACED GYPSUM BACKING BOARDS

- 1.1 General: Provide Fiberglass-mat faced, moisture resistant gypsum backer board as shown and specified.

- A. Standards: Materials and installation shall conform to the following:
1. ASTM C840 Standard Specification for Application and Finishing of Gypsum Board.
2. ASTM C1002 Standard Specification for Steel Piercing Tapping Screws for the Application of Gypsum Panel Products or Metal Plaster Bases to Wood Studs or Steel Studs
3. ASTM C1178 Standard Specification for Glass Mat Water-Resistant Gypsum Backing Panel
4. ASTM D3273 Standard Test Method for Resistance to Growth of Mold on the Surface of Interior Coatings in an Environmental Chamber
5. ASTM D6329 Standard Guide for Developing Methodology for Evaluating the Ability of Indoor Materials to Support Microbial Growth Using Static Environmental Chambers.
6. ASTM E96 Standard Test Methods for Water Vapor Transmission of Materials
7. Tile Council of North America, Inc. (TCNA): TCA Handbook for Ceramic Tile Installation, Current Edition.

2.1 Materials:

- A. Manufacturer: Georgia-Pacific Gypsum LLC, (800) 225-6119, internet: www.buildgp.com

- B. Fiberglass-Mat Faced Gypsum Backing Board: DensShield Fireguard Tile Backing board complying with ASTM C1178, Type X, Square edges, 4" wide in maximum lengths available to minimize end joint conditions, 5/8" thick. Surfacing: Coated fiberglass mat on face, back and long edges.
1. General use panels: 5/8" DensShield Fireguard Tile Backer, Georgia-Pacific Gypsum.

- C. Fasteners: Screws meeting ASTM C1002, with corrosion resistant treatment. Size and type per manufacturer's recommendations:
1. Walls (Steel Frame): Bungle head, fine thread, sharp point rust resistant drywall screw
2. Walls (Walls Frame): Bungle head, coarse thread, sharp point rust resistant screw

- D. Metal Framing, Trim, joint treatment, adhesives, acoustical sealant, and sound attenuation insulation: Refer to Section 09260 Gypsum Board Systems

3.1 Installation

- A. Install DenShield at all tile walls excluding hood area as indicated on drawings.

- B. General: Install in accordance with ASTM C840, manufacturer's recommendations and TCA Handbook for Ceramic Tile Installation.
1. Manufacturers Recommendations: refer to Current "Product Catalog", Georgia Pacific Gypsum.
a. Attach DensShield Tile Backer with grey side facing the interior. Tile should be applied on the grey coated side of DensShield Tile Backer. Cut panel to required size and make cutouts. Fit ends and edges closely. Do not leave gaps between panels.
b. DensShield Tile Backer may be cut by using a utility knife to score, then snap, working from the grey face side.
c. For walls, when used as a tile substrate a minimum 20-gauge steel or wood framing should be spaced no greater than 24" o.c. for 5/8" DensShield Tile Backer. Board can be applied horizontally or vertically.
d. Fasteners shall be spaced 6" o.c. for walls for wood and steel framing. Do not countersink. Drive fasteners flush with grey coated surface. See manufacturer installation Fastener Guide for proper selection.
e. In all corners, imbed with a bead of flexible sealant when installing panels into corner. Apply self-adhesive 2" wide fiberglass mesh tape and bed tape on all joints and corners with material used to set tiles.
f. Caulk or seal fixture/plumbing penetrations and abutments to dissimilar materials.
g. Do not use all purpose joint compound or tape in wet areas.
h. Do not apply DensShield Tile Backer directly to concrete or masonry block. Framing or furring of the walls is necessary.
i. DensShield Tile Backer should not be used for exterior installations.
j. DensShield Tile Backer panels should not be used as a base for nailing and mechanical fastening.
k. DensShield Tile Backer has a built in moisture barrier. Never install vapor retarders directly behind DensShield Tile Backer panels. In retrofit applications, some paints or other wall coverings may constitute a vapor barrier; remove or effectively penetrate these coverings prior to installing DensShield Tile Backer panels.

- C. Refer to Section 09260 Gypsum Board Systems for additional installation and sound treatment instructions

SECTION 09330 - QUARRY TILE

- 1.1 General: Provide quarry tile flooring and base as shown and specified.

- A. Standards: Materials and installation shall conform to the following:
1. ANSI A137.1 "Ceramic Tile."
2. TCA "Handbook for Ceramic Tile Installation."

2.1 Materials:

- A. Manufacturers:
1. Quarry Tile: Daltile, (877) 556-5728, internet: http://daltile.com
a. For ordering purposes, email all orders to chipotle@daltile.com
2. Waterproofing, Setting and Grouting Materials:
a. Setting and Grouting Materials and Tile Base Membrane: Mapei
i. For ordering purposes, email all orders to chipotle@daltile.com
ii. For technical questions, contact Mapei, (800) 992-6273, internet: www.mapei.com

- B. Quarry Tile: Daltile 6" x 6" x 1/2" Quarry Textures with 5" base as scheduled on finish plan and appropriate trim; Color: "Ashen Gray" OT03
1. Entire Kitchen Area: Provide non-abrasive finish quarry tile.
2. Rest Rooms: Provide non-abrasive finish quarry tile.
3. Outside Corner Cove Base (Kitchen): #QC-L (or R)-3565 5" x 6"
4. Inside Corner Cove Base: #C8-3565 1" x 5"
5. Bullnose Coveless Base: #Q-1665, 6" x 6".
6. Bullnose Corner Coveless Base: #QCRL-1665, 6" x 6".

- C. Waterproofing for elevated floor slabs: Mapei, Mapelastic AquaDefense, Premium Waterproofing and Crack Isolation Membrane
D. Setting Adhesive: Mapei, Ultraflex 3, Color: Gray
E. Grout: Mapei, Kerapoxy IEG CQ, Color: #9, "Gray", 1/4" grout joints.
F. Quarry Tile Base Membrane: Mapei, Mapelastic AquaDefense, Premium Waterproofing and Crack Isolation Membrane

3.1 Installation

- A. Preparation: Clean substrate surfaces, scheduled to receive quarry tile, thoroughly and remove all coatings that may impair bond.
1. Center tile fields both directions in each floor area. Adjust layout to minimize tile cutting. Avoid tile less than one-half size. Locate cuts to be least conspicuous.
2. Maintain units uniformly "in plane." Provide straight, uniform joint widths and grout lines.

- B. Elevated Floor Slabs: Install waterproofing membrane at elevated floor slab surfaces scheduled to receive quarry tile floor finish. Install membrane materials in accordance with manufacturer's installation instructions to produce a waterproof membrane of uniform minimum 30 mil thickness bonded securely to substrate.
1. Extend waterproofing up vertical wall surfaces minimum 10" high.
2. Extend membrane down into floor drain flanges to assure continuous waterproofing at drainage points.

- C. Wet Areas: Install waterproofing membrane at all quarry tile wall base. Install membrane materials in accordance with manufacturer's installation instructions to produce a waterproof membrane of uniform minimum 30 mil thickness bonded securely to substrate.
1. Extend waterproofing up all vertical wall surfaces receiving quarry tile base minimum 10" high. Extend waterproofing membrane 10" minimum horizontally from all vertical wall surfaces receiving quarry tile base.

- D. Installation: Install, grout and clean ceramic tile in accordance with referenced TCA installation details and ANSI standard specifications for setting methods scheduled.
1. Floors: Latex-portland cement mortar on concrete; TCA detail F113 and ANSI A108.5, grout ANSI A108.10.
2. Base: Latex-portland cement mortar on cement board.

SECTION 09340 - CERAMIC TILE

- 1.1 General: Provide ceramic wall tile as shown and specified.

- A. Standards: Materials and installation shall conform to the following:
1. ANSI A137.1 "Ceramic Tile."
2. TCA "Handbook for Ceramic Tile Installation."

2.1 Materials:

- A. Manufacturers:
1. Ceramic Tile and Accent Tile: Daltile, P: (877) 556-5728, internet: http://daltile.com
a. For ordering purposes, email all orders to chipotle@daltile.com

- B. Ceramic Tile:
1. Kitchen Tile, or as noted in plans, Series - Finish Line Glazed Ceramic Tile:
a. Color - White FL90, Semi-Gloss, Size - 4 x 16, Pattern - Stacked Bond
2. Accent Tile, Series - Color Wheel Glazed Ceramic
a. Color - Chipotle Brick Metallic 1.0 #9999710686, Size - 3 x 12, Pattern - Stacked Bond
b. Alternate Accent Tile only when approved by Arch PM and Chipotle DM
i. Series - Remedy, Color - Alchemy RD25, Size - 2 x 9, Pattern - Stacked Bond
ii. Series - Marrazzi, Color - Artesen AT25, Size - 2 x 4, Pattern - Brickjoint Mosaic

- C. Setting Adhesive: Thinset Mortar, Mapei, Ultraflex LFT - Gray

- D. Grout:
1. Kitchen Tile or as noted in plans
a. Mapei, Series - Flexcolor CQ - Gray #09, 1/8" grout joints.

2. Accent Tile
a. Mapei, Series - Flexcolor CQ - Chocolate #07, 1/8" grout joints.

3.1 Installation

- A. Preparation: Clean substrate surfaces scheduled to receive ceramic tile thoroughly and remove all coatings that may impair bond.
1. Protect surrounding work from damage.
2. Remove any curing compounds or other contaminants.
3. Vacuum clean surfaces and damp clean.
4. Install cementitious backer board or glass-mat faced gypsum backing board as indicated in drawings in accordance with ANSI A108.11 and board manufacturer's instructions. Tape joints and corners, cover with skim coat of dry-set mortar to a feather edge.
5. Prepare substrate surfaces for adhesive installation in accordance with adhesive manufacturer's instructions.
B. Kitchen:
1. Install, grout and clean ceramic tile in accordance with referenced TCA installation details and ANSI standard specifications for setting methods scheduled.
2. Lay tile in horizontal stack bond, following detail drawings for layout considerations. Horizontal rows of tile shall be full-height courses, unless noted otherwise.
3. Arrange pattern so that a full tile or joint is centered on each wall horizontally and that no tile less than 1/2 width is used at the ends of the wall. Exception: when one end of the wall is a tile-to-gypsum board transition. Do not interrupt tile pattern through openings.
4. Use specified stainless steel corner guards at tile-to-tile and tile-to-FRP outside corners.
5. Use corner bead of 100% silicone sealant, color to match grout, at inside corners where tile meets tile.
6. Use corner bead of 100% silicone sealant, white, at inside corners where tile meets paint gyp. board, tile meets FRP or tile meets aluminum.
7. Cut and fit tile to penetrations through tile, leaving sealant joint space. Place tile joints uniform in width, subject to variance in tolerance allowed in tile size. Make joints watertight, without voids, cracks, excess mortar, or excess grout.
8. Sound tile after setting. Replace hollow sounding units.
9. Keep expansion joints free of adhesive or grout. Allow time to set for a minimum of 48 hours prior to grouting. Apply sealant to junction of tile and dissimilar materials and junction of dissimilar planes. Refer to section 07900 Joint Sealers.
10. Clean tile and grout surfaces.

CONSULTANT:



CLIENT:



CHIPOTLE MEXICAN GRILL, INC.
PO BOX 16266
COLUMBUS, OH 43218-2666
TELEPHONE: (614) 318-2482
INTERNET: WWW.CHIPOTLE.COM

COPYRIGHT 2024
THIS DRAWING IS AN INSTRUMENT OF SERVICE AND AS SUCH REMAINS THE PROPERTY OF CHIPOTLE MEXICAN GRILL, INC. PERMISSION FOR USE OF THIS DOCUMENT IS LIMITED AND CAN BE EXTENDED ONLY BY WRITTEN AGREEMENT WITH CHIPOTLE MEXICAN GRILL, INC.

PROJECT INFORMATION:

STORE NO.: 5037
HUNTLEY
12990 ROUTE 47, LOT 4B
HUNTLEY, IL 60142

SEAL:



MATTHEW M. WILKUS
LICENSE #001.023967
(EXPIRES 11/30/2024)

PROJECT NO. 2023-0175
DRAWN BY JSB_DVA
CHECKED BY DVA, NSG, KAM, MMW

ISSUE RECORD:
02/12/2024 PERMIT SUBMITTAL
03/15/2024 BID SET
05/03/2024 CONSTRUCTION SET

REVISIONS:

TITLE:

ARCHITECTURAL
SPECIFICATIONS

SHEET NUMBER:

G015

SECTION 09510 - SUSPENDED CEILING SYSTEMS

- 1.1 General: Provide acoustical ceiling systems as shown and specified.
- A. Standards: Materials and installation shall conform to the following:
1. CISCA "Acoustical Ceilings - Use and Practice."
 2. ASTM C635.
 3. ASTM C636.
- B. Related Sections:
1. 09515 Cementitious Wood Fiber Acoustical Panels: Suspension system.
- 2.1 Materials:
- A. Manufacturer:
1. USG Interiors, Inc., (800) 950-3839, www.usg.com
 2. Pittcon Industries, (800) 637-7638, www.pittconindustries.com
- B. Ceiling Panels: USG "Sheetrock Lay-In ClimaPlus No. 3270" ceiling panels with white, stipple texture, vinyl facing, 24" x 48" x 1/2".
- C. Light Pocket: Pittcon "LP-700-800", White, Height of cove should be field verified by GC to end on a full tile height.
1. Light pocket can have up to 6 week lead time and should be ordered as soon as possible.
 2. Light pocket endcap should only be installed when the end of the cove is not against a wall.
- D. Suspension System: Provide intermediate duty, structural class, direct hung systems adequate to support light fixtures, ceiling diffusers and other normal accessories.
1. Exposed "Tee" Grid System for use with Lay-In Ceiling panels: USG "Donn DX System" non-fire rated with 15/16" exposed face, cold-rolled galvanized steel with aluminum face cap, white paint finish on exposed surfaces. Provide hemmed edge aluminum wall angles, 15/16" exposed leg, white paint finish matching exposed grid.
 2. Concealed "Tee" Grid System for use with Painted Gypsum Board Ceilings & Soffits or with Cementitious Wood Fiber Acoustical Panels (Tectum): USG "DGLW" Heavy Duty Drywall Suspension System with 1 5/8" deep by 1 1/2" wide main tees and 1 1/2" deep by 1 1/2" wide cross tees.
 3. Hanger Wire: No. 12 SWG galvanized steel wire.
 4. Heavy Duty "Tee" Grid System for use with Felt Baffle Ceiling System: USG Donn Brand DX/L with 15/16" wide face tees, color: black
- 3.1 Installation
- A. Install acoustical ceiling materials and suspension systems in strict accordance with manufacturer's recommendations, complying with governing regulations and industry standards applicable to the work.
- B. Suspension system installation shall be laser leveled with a maximum surface leveling tolerance of 1/8" in 12'-0".
- C. Install exposed Tee suspension systems with main tees nominally 12 ft long spaced 48 in O.C. and cross tees nominally 4 feet long spaced 24 in O.C.
- D. Install concealed Tee suspension systems with main tees nominally 12 ft long spaced 24 inches O.C. and cross tees nominally 2 ft long spaced 48 in O.C.
- E. Hanger wire shall be spaced 48" O.C. along main tees, at all four corners of light fixtures (where applicable), at midpoint of cross tees adjacent to light fixtures and duct outlets, and adjacent to main tee splices.
- F. Secure wire hangers by looping and wire-tying either directly to building structure or to hangers that are secure and appropriate for substrate.
- G. Provide edge trim molding at perimeter of acoustical ceiling installation and intermediate vertical surfaces. Use maximum lengths. Miter trim corners to Provide tight, accurate joints. Connect moldings securely to substrate surfaces.

SECTION 09653 - RUBBER WALL BASE

- 1.1 General: Provide resilient rubber wall base as shown and specified.
- A. Standards: Materials and installation shall conform to the following:
1. ASTM D 2240 Rubber - 85 Shore A
- 2.1 Materials:
- A. Manufacturer: Johnsnite, Inc., (800) 899-8916, internet: www.johnsonite.com
1. Basis-of-Design Product Rubber Wall Base:
 - a. Resilient Rubber:
 1. .125" (3.17 mm) Thickness
 2. "Black" color
 3. Straight (toeless) or coved as specified on finish plan
 4. Inside and outside corners with 4" returns.
 - B. Alternate Wall Base only when approved by Arch PM and Chipotle DM.
 1. Vinyl Wall Base
 - a. .125" (3.17 mm) Thickness
 - b. "Black" color
 - c. Straight (toeless) or coved as specified on finish plan
 - d. Inside and outside corners with 4" returns.
- C. Setting Adhesive:
1. For porous surface applications: Johnsonite 960 Acrylic Cove Base Adhesive.
 2. For non-porous surface applications: Johnsonite 946 Contact Bond Adhesive or polymer based alternative.
- 3.1 Installation:
- A. Preparation: Clean substrate surfaces scheduled to receive resilient rubber and vinyl wall base thoroughly and remove all coatings that may impair bond. A uniform temperature of at least 65 degrees Fahrenheit shall be maintained for 24 hours before, during and after the installation is completed. The wall base and adhesives shall be conditioned in the same manner. Coiled wall base shall be uncoiled and lay flat for at least 24 hours at 65 degrees Fahrenheit prior to installation. Floor and walls shall be clean, dry, and free of dust, all paints, wallpaper, and all other foreign material, which may affect proper adhesive bonding. Wall base may be installed on interior plaster, gypsum wall board, concrete, masonry, mineral-reinforced cement board or similar porous surfaces. Wall base shall not be installed on surfaces that will be exposed to drastic temperature changes or moisture.
- B. Application: Use a 1/8" square notch trowel to apply adhesive. Allow adhesive to set up and then apply wall base in accordance with manufacturer's instructions.
- SECTION 09770 - SPECIAL WALL SURFACING - PHENOLIC INTERIOR WALL PANELS
- 1.1 General: Provide Stonewood solid phenolic panels and accessories for interior walls and millwork as shown and specified.
- 1.2 Related Sections:
- A. Section 05400 - Cold Formed Metal Framing
- B. Section 06210 - Finish Carpentry and Millwork
- C. Section 07900 - Joint Sealers
- D. Section 09260 - Gypsum Board Systems
- 1.3 Standards: Materials and construction shall conform to the following:
- A. ASTM D638 - 10 Standard Test Method for Tensile Properties of Plastics.
- B. ASTM D790 - 10 Standard Test Methods for Flexural Properties of Unreinforced and Reinforced Plastics and Electrical Insulating Materials.
- C. ASTM E84 - 12 Standard Test Method for Surface Burning Characteristics of Building Materials.
- D. NEMA Standards Publication LD3-2005: High pressure decorative laminates.

- 1.4 Design/Performance Requirements:
- A. Design and size of wall panel assemblies including wall panels, mounting system to support weight of panels.
- B. Allow for thermal movements from ambient and surface temperature changes by preventing buckling, opening of joints, overstressing of components, failure of joint sealants, failure of connections, and other detrimental effects. Base calculations on expected movement of material as defined in fabrication guidelines.
- 1.5 Quality Assurance:
- A. Manufacturer's Qualifications:
1. Sufficient plant facilities to provide quality and quantity of materials as required without delaying progress of work.
 2. Minimum of 40 years of experience in paper saturation of phenolic resin, and producing phenolic paper laminate.
- B. Fabricator:
1. Fabricated by the manufacturer, and/or;
 2. Contracted by the customer, minimum 5 years' experience in fabrication work for the size and complexity of the projects.
- C. Installer
1. Proven professional installer with a minimum of 5 years of documented experience.
 2. Approved by the manufacturer.
- 1.6 Delivery, Storage and Handling:
- A. Refer to Section 01400 Quality Requirements.
- B. Delivery: Deliver materials in manufacturer's original unopened containers/packages, with labels clearly identifying product name, manufacturer, color/texture and weight.
- C. Storage:
1. Keep panels dry and stored indoors in original packaging until installation.
 2. Store Stonewood panels on a smooth, dry, flat surface, making sure there are no bends or bowing in the load.
 3. Do not store directly on cold concrete floors as moisture may migrate.
 4. Do not store under heating units or air conditioning units.
 5. Keep load stored within outer wrap until use. Remove pallet straps once load is moved to storage area.
 6. Reseal plastic wrap if partial load is used.
 7. Keep foam dividers in place.
- D. Handling:
1. Handle materials in accordance with manufacturer's instructions.
 2. Protect materials during handling to prevent damage.
 3. When moving sheets, lift evenly to avoid dragging panels across each other and scratching the surface. PLEASE TAKE CARE NOT TO SCRATCH THE SURFACE OF THE PANEL DURING HANDLING, MACHINING AND INSTALLATION.
- 1.7 Warranty:
- A. Limited Warranty: Fibbers warrants Stonewood for a period of 10 years. Refer to www.stonewoodpanels.com for details.
- 1.8 Project Conditions:
- A. Environmental Limitations: Buildings are to be fully enclosed prior to installation with sufficient heat (70 degrees) and ventilation consistent with good working conditions for finish work.
- B. Maintain environmental conditions (temperature, humidity, and ventilation) within limits recommended by manufacturer for optimum results. Do not install products under environmental conditions outside manufacturer's absolute limits.
- C. Field Measurements: Verify locations of structural members and wall opening dimensions by field measurements before composite wall panel fabrication and indicate field measurements on Shop Drawings.
- 2.1 Manufacturer:
- A. Fiberesin Industries, Inc. PO Box 908, Oconomowoc, WI 53066. Phone: (262) 567-4427, Fax: (262) 567-4814, Web Site: www.stonewoodpanels.com Email: info@fiberesin.com
- B. Made in the United States from materials sourced in the USA.
- 2.2 Application:
- A. Apply Solid Phenolic Laminate Wall Panels at walls and other surfaces as indicated on the Drawings. Phenolic Wall Panels are architectural wall panels applied over a sheathed stud wall or other solid blocking per Drawings.
- 2.3 Interior Stonewood:
- A. Material: Solid phenolic laminate panel w/o overlay.
- B. Color: Black ND
- C. Finish: Matte
- D. Standard Size: 48"x96", fabricator to trim height to 47"
- E. Panel Thickness: 5/16", 1/2"
- F. Panel Core: HR Black
- 2.4 Minimum Material Properties
- A. NEMA Requirements:
- | Description | NEMA Requirements | |
|----------------------------|-------------------|-------|
| Dimensional Change: | 3.11 | |
| Length (Machine Direction) | 0.3% Maximum | 0.25% |
| Width (Cross Direction) | 0.7% Maximum | 0.50% |
| Density (PCF) | 82 | |
- B. Mechanical Properties:
- | Property | NEMA Requirements | |
|------------------------------|---------------------|----------------------|
| Flexural Strength ASTM D-790 | | |
| MD (psi) | 18,000 | 20,000 |
| CD (psi) | 12,000 | 16,000 |
| Flexural Modulus ASTM D-790 | | |
| MD (psi) | 1.6x10 ⁶ | 2.0 x10 ⁶ |
| CD (psi) | 1.4x10 ⁶ | 1.5x10 ⁶ |
| Tensile Modulus ASTM D-638 | | |
| MD (psi) | 18,000 | 18,000 |
| CD (psi) | 12,000 | 13,000 |
- C. Fire Resistance:
- | | Class A (0.250") | Class B (0.250") |
|--|------------------|------------------|
| Flame Spread Index - ASTM E-84 (BLDG): | 5 | 30 |
| Smoke Developed Values - ASTM E-84 (BLDG): | 5 | 105 |
| Fire Rating (Standard Product is Class B): | A | B |
- D. Manufacturing Tolerance:
- | | |
|------------------------------------|----------|
| Thickness (.156 to .375) | +/- .020 |
| Thickness (above .375 to 1.000) | +/- .030 |
| CNC Shaped Size (Length - Width) | +/- .020 |
| Drill Diameter | +/- .003 |
| Drill Depth | +/- .020 |
| CNC Hole to Hole | +/- .020 |
| CNC Hole to Edge (1 Oper) | +/- .020 |
| CNC Hole to Edge (2 Oper) | +/- .030 |
| Routing - (Slots Width and Length) | +/- .015 |
| Routing - (Slots Depth) | +/- .020 |

- 2.5 Accessories (Fasteners):
- A. Panel Fasteners: #10 x 1-1/4" flat Phillips head black oxide wood screws to be used with wood blocking and #10 x 1-1/4" flat Phillips head black oxide sheet metal screws to be used with sheet metal blocking as recommended by the manufacturer.
- B. Provide exposed fasteners with heads matching color of composite wall panels by means of factory-applied coating.
- C. Fasteners shall be designed to withstand effects of dead load and accommodate hydrothermal expansion/contraction of panel.
- D. Wall Panel Accessories: Provide components required for a complete composite wall panel assembly including trim, flashings, sealants, gaskets, fillers, closure strips, and similar items. Match material and finish of composite wall panels unless otherwise indicated.
- 3.1 Manufacturer's Execution Instructions:
- A. Compliance: Comply with manufacturer's/fabricator's/supplier's product data, handling and installation instruction/manual, shop drawings, shipping container/package ticket identification, etc.
- 3.2 Examination:
- A. Verify correct panels received including dimension, tolerance, color/texture.
- B. Verify correct attachment system received for the specific project/job.
- C. Verify all the documents including shop drawing and installation guidelines.
- D. Verify installation conditions are satisfactory to receive work of this section before the commencement
- E. Verify substrate installation is complete, flat, and true to plane.
- F. If substrate preparation is the responsibility of another installer, notify Architect of unsatisfactory preparation before proceeding.
- 3.3 Preparation:
- A. Field Measurements: Verify prior to fabrication and installation of the cladding panel.
- B. Protect surrounding areas and surfaces to preclude damage during work of this section.
- C. Lay out work before beginning installation as necessary for true, plumb and aligned panel installations.
- D. Verify locations of joints and panel lengths.
- 3.4 Installation:
- A. Conform to manufacturer's instructions and provisions of shop drawings.
- B. Install to allow hydro-thermal expansion/contraction.
- C. Use appropriate techniques/tools to work with the panel.
- D. Do not force to fit, do not bend, stretch/compress.
- E. Make cutting and fitting neat, square, and true. Where required cut, de-burr edges, and clean fillings from adjacent surfaces.
- F. Do not install damaged or questionable panels.
- G. Install solid phenolic wall panels plumb and level and accurately spaced.
- H. Anchor panels and other components of the work securely in place, with provisions for thermal and structural movement.
- I. Shim or otherwise plumb substrates receiving composite wall panels.
- J. Do not use construction adhesives to apply wall panels directly to substrates or wall board. Use mechanical fasteners only.
- 3.5 Erection Tolerances:
- A. Shim and align composite wall panel units within installed tolerance of 1/4 inch in 20 feet, non-accumulative, on level, plumb, and location lines as indicated and within 1/8 inch offset of adjoining faces and of alignment of matching profiles.
- 3.6 Field Quality Control:
- A. Manufacturer's Field Service: Provide field services to ensure product installation is in accordance with manufacturer's/fabricator's/supplier's instructions and installation manual, shop drawings etc.
- 3.7 Adjusting:
- A. Correct identified defects and irregularities.
- B. Replace damaged soiled, and discolored work.
- 3.8 Cleaning:
- A. Leave installation clean and free from residue and debris from work of this Section.
- B. Panels best cleaned with warm soapy water and rinsed with clear water; allowed to dry fully.
- SECTION 09900 - PAINTS AND COATINGS
- 1.1 General: Provide paints and coatings as shown and specified.
- A. Provide surface preparation, prime, intermediate and finish coatings for interior and exterior and existing scheduled surfaces and items.
- B. Provide Tenant-selected finishes and colors for all exposed surfaces, unless otherwise indicated.
- 1.2 Related Documents:
- A. Drawings and general provisions of the Contract, including General and Supplementary Conditions and Division 1 Specification Sections, apply to this section.
- 1.3 Summary:
- A. This section includes surface preparation and field painting of the following:
1. Exposed exterior items and surfaces.
 2. Exposed interior items and surfaces.
 3. Surface preparation, priming, and finish coats specified in this Section are in addition to shop priming and surface treatment specified in other Sections.
- 1.4 Quality Assurance:
- A. Applicator Qualifications: Engage an experienced applicator that has completed painting system applications similar in material and extent to that indicated for this Project with a record of successful in-service performance.
- B. Source Limitations: Obtain block fillers, primers and undercoat materials for each coating system from the same manufacturer as the finish coats.
- C. Provide lead free prime and finish coatings. All top coatings shall be mold and mildew resistant.
- 1.5 Delivery, Storage and Handling:
- A. Deliver materials to the Project Site in manufacturer's original, unopened packages and containers bearing manufacturer's name and label, and the following information:
1. Product name or tile of material.
 2. Product description (generic classification or binder type).
 3. Manufacturer's stock number and date of manufacture.
 4. Contents by volume, for pigment and vehicle constituents.
 5. Thinning instructions.
 6. Application instructions.
 7. Color name and number.
 8. VOC content
- B. Store materials not in use in tightly covered containers in a well-ventilated area at a minimum ambient temperature of 45 degrees F (7 degrees C). Maintain containers used in storage in a clean condition, free of foreign materials and residue.
1. Protect from freezing. Keep storage area neat and orderly. Remove oily rags and waste daily. Take necessary measures to ensure that workers and work areas are protected from fire and health hazards resulting from handling, mixing and application.
- 1.6 Project Conditions
- A. Apply water-based paints only when the temperatures of surfaces to be painted and surrounding air temperatures are between 50 and 90 degrees F (10 and 32 degrees C) unless otherwise stated on the technical data bulletin.
- B. Apply solvent-thinned paints only when the temperature of surfaces to be painted and surrounding air temperatures are between 45 and 95 degrees F (7.2 and 35 degrees C).
- C. Do not apply paint in snow, rain, fog, or mist, or when the relative humidity exceeds 85 percent, or at temperatures less than 5 degrees F (3 degrees C) above the dew point, or to damp or wet surfaces.
1. Painting may continue during inclement weather if surfaces and areas to be painted are enclosed and heated within temperature limits specified by manufacturer during application and drying periods.

- 2.1 Manufacturers:
- A. Products: Subject to compliance with requirements, provide one of the products in the paint schedules.
- B. Manufacturers Names: The following manufacturer is referred to in the paint schedule by use of shortened versions of the name, which is shown below:
1. PPG Industries, Inc.
 2. Materials - No substitutions allowed.
- 2.2 Paint Materials, General
- A. Material Compatibility: Provide block fillers, primers, undercoats, and finish-coat materials that are compatible with one another and the substrates indicated under conditions of service and application, as demonstrated by manufacturer based on testing and field experience.
- B. Material Quality: Provide manufacturer's best-quality "professional" paint material of the various coating types specified. Paint-material containers not displaying manufacturer's product identification will not be acceptable.
- Colors: Color guided selected by owner and will be strictly adhered too, unless otherwise noted.
- C. Exterior Coatings:
- Exterior Ferrous Metals:
- Preparation: Remove all visible oil, grease, soil, rust and all other soluble contaminates from steel surface. Uniformly roughen surface with 150 grit paper. Remove all dust before solvent cleaning by the use of stiff bristle brush.
- Prime: (1) coat PPG; 4020PF Series Pitt-Tech Plus Int/Ext DTM Acrylic Industrial Primer (90 g/L VOC): Applied at a dry film thickness of not less than 2.0 to 4.0 mils.
- Finish: (2) coats PPG; 4216 Plus HP Series Pitt-Tech Plus Semi-Gloss DTM Industrial Enamels (90 g/L VOC): Applied at a dry film thickness of not less than 2.0 to 4.0 mils.
- Application: Conventional or HVLP (high volume low pressure)
- Exterior and Interior Gas Piping:
- Preparation: Remove all visible oil, grease, soil, rust and all other soluble contaminates from pipe surface. Remove all dust before solvent cleaning by the use of stiff bristle brush.
- Prime: (1) coat PPG; 4020PF Series Pitt-Tech Plus Int/Ext DTM Acrylic Industrial Primer (90 g/L VOC): Applied at a dry film thickness of not less than 2.0 to 4.0 mils.
- Finish: (2) coats PPG; 4216 Plus HP Series Pitt-Tech Plus Semi-Gloss DTM Industrial Enamels (90 g/L VOC): Applied at a dry film thickness of not less than 2.0 to 4.0 mils.
- Application: Conventional or HVLP (high volume low pressure)
- Exterior Patio Walling:
- Preparation: Remove all visible oil, grease, soil, loose paint, rust and all other soluble contaminates from steel surface. Remove all dust before solvent cleaning SSPC-SP1 by the use of stiff bristle brush. SSPC-SP3 may be required as a more aggressive preparation to remove loose mill scale, loose rust, loose paint and other loose detrimental foreign matter from the surface. Performance is better with more aggressive preparation.
- Prime: (1) coat PPG; 95-3300 Durathane DTM Urethane Mastic (250 g/L VOC): Applied at a dry film thickness of not less than 3.0 to 5.0 mils.
- Finish: (1) coat PPG; 95-3300 Durathane DTM Urethane Mastic (250 g/L VOC): Applied at a dry film thickness of not less than 3.0 to 5.0 mils.
- Application: Conventional or HVLP (high volume low pressure) be done with conventional spray or airless equipment or brush or roller.
- Exterior Prefinished Metal Wall Panels:
- Preparation: Before applying primer or other surface treatments, clean galvanized metal surface to SSPC-SP1 that could impair bond of the various coatings. Remove oil, grease and soap film before priming use of Krud Kutter Metal Clean & Etch may be required on bare or new galvanized. Surface must be clean, dry and free of contaminants, including salt deposits. Additional prep may be needed to SSPC-SP2. Schedule cleaning and painting so dust and other contaminants from the cleaning process will not fall on wet, newly painted surfaces.
- Note: Some selected areas of bare concrete surfaces will require (1) coat of Perma Crete 4-603XI Alkali Resistant Concrete Primer before steel installation over all concrete surfaces.
- Owner Option 1:
- Prime: (1) coat XIM Primer Bond - Applied at a dry film thickness of not less than 1.5 to 2.0 mils.
- Finish: (2) coats PPG; 90-1110 Series Pitt-Tech Satin DTM Industrial Enamels (90 g/L VOC): Applied at a dry film thickness of not less than 2.0 to 4.0 mils.
- Owner Option 2:
- Prime: (1) coat PPG; 97-245 Pitt-Guard DTR Epoxy Mastic Primer (263 g/L VOC): Applied at a dry film thickness of not less than 4.0 to 7.0 mils.
- Finish: (2) coats PPG; 95-3300 Durathane Urethane Mastic (240 g/L VOC): Applied at a dry film thickness of not less than 2.0 to 4.0 mils.
- Owner Option 3 (Low VOC):
- Prime: (1) coat PPG; Amerlock 2 Fast Dry VOC Compliant Epoxy (84 g/L VOC): Applied at a dry film thickness of not less than 4.0 to 6.0 mils.
- Finish: (2) coats PPG; Amershield VOC Aliphatic Urethane (84 g/L VOC): Applied at a dry film thickness of not less than 5.0 to 8.0 mils.
- Application: Conventional or HVLP (high volume low pressure) be done with conventional spray or airless equipment or brush or roller.
- Exterior Galvanized Metal:
- Preparation: Before applying primer or other surface treatments, clean galvanized metal surface to SSPC-SP1 that could impair bond of the various coatings. Remove oil, grease and soap film before priming use of Krud Kutter Metal Clean & Etch may be required on bare or new galvanized. Surface must be clean, dry and free of contaminants, including salt deposits. Additional prep may be needed to SSPC-SP2. Schedule cleaning and painting so dust and other contaminants from the cleaning process will not fall on wet, newly painted surfaces.
- Note: Some selected areas of bare concrete surfaces will require (1) coat of Perma Crete 4-503 Concrete Primer before steel installation over all concrete surfaces.
- Owner Option 1:
- Prime: (1) coat PPG; 6-209 SpeedHide Galvanized Metal Primer (400 g/L VOC): Applied at a dry film thickness of not less than 3.0 to 5.0 mils.
- Finish: (2) coats PPG; 4216 Plus HP Series Pitt-Tech Plus Semi-Gloss DTM Industrial Enamels (90 g/L VOC): Applied at a dry film thickness of not less than 2.0 to 4.0 mils.
- Owner Option 2:
- Prime: (1) coat PPG; 97-245 Pitt-Guard DTR Epoxy Mastic Primer (263 g/L VOC): Applied at a dry film thickness of not less than 4.0 to 7.0 mils.
- Finish: (2) coats PPG; 95-3300 Durathane Urethane Mastic (240 g/L VOC): Applied at a dry film thickness of not less than 2.0 to 4.0 mils.
- Owner Option 3 (Low VOC):
- Prime: (1) coat PPG; Amerlock 2 Fast Dry VOC Compliant Epoxy (84 g/L VOC): Applied at a dry film thickness of not less than 4.0 to 6.0 mils.
- Finish: (2) coats PPG; Amershield VOC Aliphatic Urethane (84 g/L VOC): Applied at a dry film thickness of not less than 5.0 to 8.0 mils.
- Application: Conventional or HVLP (high volume low pressure) be done with conventional spray or airless equipment or brush or roller.

CONSULTANT:



CLIENT:




CHIPOTLE MEXICAN GRILL, INC.
PO BOX 16266
COLUMBUS, OH 43216-2666
TELEPHONE: (614) 318-2482
INTERNET: WWW.CHIPOTLE.COM

COPYRIGHT 2024
THIS DRAWING IS AN INSTRUMENT OF SERVICE AND
AS SUCH REMAINS THE PROPERTY OF CHIPOTLE
MEXICAN GRILL, INC. PERMISSION FOR USE OF THIS
DOCUMENT IS LIMITED AND CAN BE EXTENDED ONLY
BY WRITTEN AGREEMENT WITH CHIPOTLE MEXICAN
GRILL, INC.

PROJECT INFORMATION:

STORE NO.: 5037
HUNTLEY
12990 ROUTE 47, LOT 4B
HUNTLEY, IL 60142

SEAL:

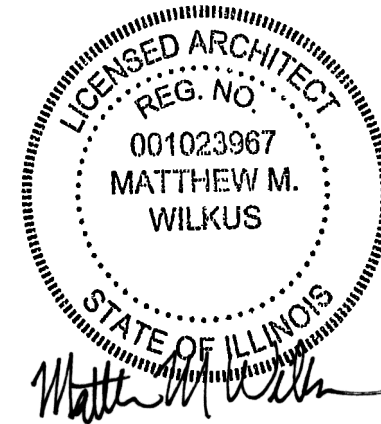

May 06, 2024

MATTHEW M. WILKUS
LICENSE #001,023967
(EXPIRES 11/30/2024)

PROJECT NO. 2023-0175
DRAWN BY JSB, DVA
CHECKED BY DVA, NSG, KAM, MMW

ISSUE RECORD:

DATE	DESCRIPTION
02/12/2024	PERMIT SUBMITTAL
03/15/2024	BID SET
05/03/2024	CONSTRUCTION SET

REVISIONS:

TITLE:

ARCHITECTURAL
SPECIFICATIONS

SHEET NUMBER:

G016

Exterior CMU Primer:

CMU Preparation: Mortar should cure for at least 30 days and preferably 90 days prior to priming. Fill block with an appropriate block filler. Surfaces previously coated with water thinned cement-based paint must be prepared with extra care. If the material appears to be adhering tightly, a masonry sealer may be applied to seal the surface. Check adhesion by applying a piece of masking tape. If the sealer peels off and has loose particles, remove all chalking or crumbling material, re-seal and re-check adhesion.

Field Preparation: Surfaces to be coated must be dry, clean, sound, and free from all contamination including loose and peeling paint, dirt, grease, oil, wax, concrete curing agents and bond breakers, chalk, efflorescence, mildew, rust, product fines, and dust. Remove loose paint, chalk, and efflorescence by wire brushing, scraping, sanding, and/or pressure washing. Putty all nail holes and caulk all cracks and open seams. Sand all glossy, rough, and patched surfaces. Feather back all rough edges to sound surface by sanding.

Prime: (2) Coats PPG; Speedhide Interior/Exterior Masonry Hi Fill Latex Block Filler

Application: Brush, Roll or Spray

Exterior Stucco/EIFS Surfaces (including wet areas):

Preparation: Remove all visible oil, grease, soil and all other foreign substances with cleaning solutions and/or scrapers. Allow to dry and sand all areas that need smoothing and dust off.

Prime: (1) coat PPG; 4-603 Perma-Crete Alkali Resistant Primer (100 g/L VOC): Applied at a dry film thickness of not less than 1.2 to 1.9 mils.

Finish: (2) coats PPG; 4-22 Perma-Crete Hi-Build Acrylic (100 g/L VOC): Applied at a dry film thickness of not less than 3.2 to 5.8 mils.

Application: Airless spray with back roll using 3/4" nap roller.

Exterior Wood:

Preparation: Remove all visible oil, grease, soil and all other foreign substances with cleaning solutions and or scrapers. Allow to dry and sand all areas that need smoothing and dust off.

Prime: (1) coat PPG; 17-921 Seal Grip Primer Sealer (100 g/L VOC): Applied at a dry film thickness of not less than 2.0 to 4.0 mils.

Finish: (2) coats PPG; 70-501 Manor Hall Exterior Semi-Gloss or PPG Acri-Shield Semi-Gloss PP649 (50 g/L VOC): Applied at a dry film thickness of not less than 1.5 to 3.0 mils.

Application: Brush, Roll or Spray

D. Interior Coatings:

Interior Metals: (Doors, door frames, where indicated)

Preparation: Remove all visible rust, oil, grease, soil and all other foreign substances with cleaning solutions and/or scrapers. Allow to dry and sand all areas that need smoothing and dust off.

Prime: (1) coat PPG; 4020PF Series Pitt-Tech Plus Int/Ext DTM Acrylic Industrial Primer (90 g/L VOC): Applied at a dry film thickness of not less than 2.0 to 4.0 mils. (Repaints only require spot prime on bare metal surfaces.)

Finish: (2) coats PPG; V-50-410 Breakthrough Semi-gloss Sheen Acrylic (250 g/L VOC): Applied at a dry film thickness of not less than 1.4 to 2.0 mils.

Application: Conventional spray, HVLP or Airless spray. Touch-ups shall be done with conventional spray or airless equipment or brush or roller.

Interior Metals: (Metal Deck if indicated on Finish Plan)

Preparation: Remove all visible rust, oil, grease, soil and all other foreign substances with cleaning solutions and allow to dry before priming.

Prime: (1) coat PPG; 4020PF Series Pitt-Tech Plus Int/Ext DTM Acrylic Industrial Primer (90 g/L VOC): Applied at a dry film thickness of not less than 2.0 to 4.0 mils. (Primer only required on unpainted decking or to spot prime bare areas in decking.)

Finish: (2) coats PPG; 90-1110 Pitt-Tech Plus Satin Acrylic (100 g/L VOC): Applied at a dry film thickness of not less than 2.0 to 4.0 mils.

Application: Conventional spray, HVLP or Airless spray. Touch-ups shall be done with conventional spray or airless equipment or brush or roller.

Interior Gyp. Bd.:

Preparation: Remove all visible oil, grease, soil and all other foreign substances with cleaning solutions. Fill hairline cracks, holes and other defects with filler compatible with finish coats. Sand smooth all areas filled and/or areas to make a smooth overall finish.

Prime: (1) coat PPG; 9-900 Pure Performance Acrylic Primer (0 g/L VOC): Applied at a dry film thickness of not less than 1.4 to 2.0 mils. (Spot prime required only on repaint projects.)

Finish: (2) coats PPG; Pure Performance Zero VOC Eggshell 9-500 Series, sheen as shown on finish plan: Applied at a dry film thickness of not less than 1.5 to 2.0 mils.

Application: Conventional spray, HVLP or Airless spray. Touch-ups shall be done with conventional spray or airless equipment or brush or roller.

Interior Wood Trim and Plywood - Clear Polyurethane Finish: (Plywood finishes shall be shop applied in a controlled environment)

Shop Preparation: Scuff sand between coats.

Shop Finish: (2) coat, ML Campbell Krystal conversion varnish, Clear Dull Sheen

Application: Spray

Field Preparation: All cuts in field are to be sanded smooth. Scuff sand between coats.

Field Finish: (2) coat, ML Campbell High Performance Pre-Cat Lacquer, Clear Dull Sheen

Application: Wipe on with t-shirt rag.

Exterior Traffic Safety Marking.:

Preparation: All surfaces must be clean, dry and free from oil, grease, antifreeze, loose sand, aggregate and chipping/peeling existing striping. Any curing compounds used on new concrete must be mechanically abraded off prior to striping. When striping on freshly sealed surfaces use caution as some sealers can affect the curing and adhesion of traffic paint. When in doubt, always test adhesion.

For complete drying and minimum dirt retention when striping parking lots, the lots should be closed to traffic for two hours minimum after painting. New asphalt and concrete should be allowed to cure for a minimum of 14 days to maximize adhesion and durability.

Owner Option 1:

Finish: (1) coat PPG; A-28868 Type II, White Zone Marking - Applied at a dry film thickness of not less than 8.6 mils.

Owner Option 2:

Finish: (1) coat PPG; A-28868 Type II, Yellow Zone Marking - Applied at a dry film thickness of not less than 8.6 mils

Application: Applying a test strip to determine dry to no- pickup time when the humidity is higher than 65%. Cone whenever necessary.

• Do not heat paint in striping system above 60 C.

• Do not apply when temperatures are below 3 C.

• Do not apply when rain is forecast.

• Do not apply when temperatures are near or below the dew point or rain is forecast within 1 hour.

• Do not thin more than 5% with acetone and then use immediately.

• Do not apply if temperature is expected to fall below freezing for 6 hours after application of paint.

Application Equipment: Apply with a high quality brush, roller, or by airless spray equipment.

Airless Spray: Pressure 2000 psi, tip 0.015" - 0.021"Spray equipment must be handled with due care and in accordance with manufacturer's recommendation. High-pressure injection of coating s into the skin by airless equipment may cause serious injury.

Brush: Polyester/Nylon Brush

Roller: All-purpose nap roller cover.

E. Color Guide: Refer to Finish Plan and drawings for exact location of all colors.

WHERE	WHAT	COLOR	SHEEN	FINISH TAG
Exterior (Roof Mounted) Gas Piping	PPG Pitt-Tech Plus Semi-Gloss Acrylic Finish 4216 Plus HP Series	Yellow	Semi-Gloss	N/A
Exterior and Interior Gas Piping, Where Exposed	PPG Pitt-Tech Plus Semi-Gloss Acrylic Finish 4216 Plus HP Series	Match surrounding finishes/verify with architect	Semi-Gloss	N/A
Exterior Ferrous Metals	PPG Pitt-Tech Plus Semi-Gloss Acrylic Finish 4216 Plus HP Series	PPG 1001-6 "Knight's Armor"	Semi-Gloss	N/A
Exterior Wood	PPG Manor Hall Acrylic Semi-Gloss 70-501 Series or PPG Acri-Shield Acrylic Semi-Gloss PP649 Series	PPG 1001-6 "Knight's Armor"	Semi-Gloss	N/A
Interior Doors, Door Frames, Rails and Rail Frames, Where Specified	PPG Breakthrough 50 Acrylic Satin	PPG V52-90 Black	Satin	D1
Interior Ferrous Metals, Where Specified	PPG Breakthrough 250 Acrylic Eggshell V50-410 Series	PPG 1013-5 "Victorian Pewter"	Eggshell	N/A
Dining Room and Hallway Gyp. Bd.	PPG Pure Performance Zero VOC Semi-Gloss 9-500 as indicated on finish plan	PPG 1001-3 "Thin Ice"	Semi-Gloss	P4
Dining Room and Hallway Gyp. Bd.	PPG Pure Performance Zero VOC Eggshell 9-310 as indicated on finish plan	PPG 1001-3 "Thin Ice"	Eggshell	P3
Dining Room and Hallway Gyp. Bd. Ceiling	PPG Pure Performance Zero VOC Flat 9-100 Series or PPG Speedhide 6-4110XI Flat	PPG 1041-1 "Moonlit Snow"	Flat	C3
Restroom, Cooking, Kitchen and Serving Area Soffit Gyp. Bd.	PPG Pure Performance Zero VOC Eggshell 9-500 Series	PPG 1041-1 "Moonlit Snow"	Eggshell	C3
Patio Railing	Durethane DTM Urethane 95-3300 Series	PPG 1001-6 "Knight's Armor"	Gloss	N/A

3.1 Installation:

A. Examination:

1. Verify that site environmental conditions are appropriate for application of coatings specified.

2. Immediately prior to coating application, ensure that surfaces to receive coatings are dry.

3. Ensure that moisture-retaining substrates to receive coatings have moisture content within tolerances allowed by coating manufacturer, using moisture measurement techniques recommended by coating manufacturer.

4. Immediately prior to coating application, examine surfaces to receive coatings for surface imperfections and for contaminants which could impair performance or appearance of coatings, including but not limited to, loose primer, rust, scale, oil, grease, mildew, algae, or fungus, stains or marks, cracks, indentations, or abrasions.

5. Correct the above conditions and any other conditions which could impair performance or appearance of coatings in accordance with specified surface preparation procedures before proceeding with coating application.

B. Preparation:

1. Do not start work until surfaces to be finished are in proper condition to produce finished surfaces of uniform, satisfactory appearance.

2. Stains and Marks: Remove completely, if possible, using materials and methods recommended by coating manufacturer; seal with shellac or other coating acceptable to paint manufacturer stains and marks that might bleed through paint finishes which cannot be completely removed.

3. Remove or protect hardware, electrical plates, mechanical grilles and louvers, lighting fixture trim, and other items not indicated to receive coatings which are adjacent to surfaces to receive coatings.

4. Remove mildew from impervious surfaces by scrubbing with solution of disodium phosphate and bleach. Rinse with clean water and allow substrate to thoroughly dry.

5. For specific substrate preparation, see individual specifications.

6. Provide necessary staging, ladders, shield, protective coverings and drop cloths. Protect floors, walls and adjacent work and materials. Remove and properly replace temporary protection and coverings removed from any part of the work or finish. Repair damage at Contractor's expense.

C. Application:

1. General: Mix, prepare and apply paint according to manufacturer's written instructions.

a. Use applicators and techniques best suited for substrate and type of material being applied.

b. Do not apply high-performance coatings over dirt, rust, scale, grease, moisture, scuffed surfaces, or conditions detrimental to forming a durable coating film.

c. Coating surface treatments, and finishes are indicated in the coating system descriptions.

d. Provide finish coats compatible with primers used.

e. The term "exposed surfaces" includes areas visible when permanent or built-in fixtures, convector covers, grilles, covers for finned-tube radiation, and similar components are in place. Extend coatings in these areas, as required, to maintain system integrity and provide desired protection.

2. Application Procedures: Apply coatings by brush, roller, spray, or other applicators according to manufacturer's written instructions.

a. The number of coats and film thickness required is the same regardless of application method.

b. Completed Work: Match approved Samples for color, texture, and coverage. Remove, refinish, or recoat work that does not comply with specified requirements as directed by Tenant. Paints and coatings work is subject to acceptance by the Tenant.

c. Keep brushes and rollers clean, free from contamination and suitable for the finish required.

d. Unless otherwise indicated, allow exterior paints to dry for 48 hours and interior paints to dry for 24 hours between coats.

e. Sand lightly and remove dust between coats to achieve required finish.

f. Finished surfaces shall be uniform in finish and color and free of brush marks, sagging, holidays, corduroy and other imperfections. Coverage and hide shall be complete.

g. Edges of paint or finish adjoining other materials or colors shall be sharp and clean without overlapping. Cut paint in neatly around glass or other edges.

h. Paints and coatings work is subject to acceptance by the Tenant. Correct unsatisfactory work not complying with these specifications as directed by the Tenant.

D. Cleaning:

1. After completing painting, clean glass and paint splattered surfaces. Remove splattered paint by washing and scraping without scratching or damaging adjacent finished surfaces.

E. Protection:

1. Protect work of other trades, whether being painted or not, against damage from painting. Correct damage by cleaning, repairing or replacing, and repainting, as approved by Architect / Tenant.

2. Provide "Wet Paint" signs to protect newly painted finishes. After completing painting operations, remove temporary protective wrappings provided by others to protect their work.

3. After work of other trades is complete, touch up and restore damaged or defaced painted surfaces.

F. Maintenance: Furnish extra paint materials from the same production run as the materials applied in the quantities described below. Package paint materials in unopened, factory-sealed containers for storage and identify with labels describing contents. Deliver extra materials to the Tenant.

1. Provide one gallon of paint and wood stain of each type and color required for maintenance purposes. Provide original, unopened, labeled containers with color samples and a list of project use.

DIVISION 10 - SPECIALTIES

SECTION 10522 - PORTABLE FIRE EXTINGUISHES

1.1 General: Provide portable fire extinguishers as shown and specified.

A. Standards: Materials and installation shall conform to the following:

1. NFPA 10 "Standard for Portable Fire Extinguishers.

2.1 Materials:

A. Provide minimum 10 lb. capacity fire extinguishers in quantity and type complying with local code and fire regulations requirements.

1. Provide new fire extinguishers fully loaded, tested, UL and FM labeled and listed and ready for use.

2. Provide manufacturer's recommended mounting brackets and hardware.

3.1 Installation:

A. Install fire extinguishers in accordance with manufacturer's installation instructions, at heights and locations acceptable to the local fire regulations enforcement authority

SECTION 10700 - EXTRUDED ALUMINUM CANOPY

1.1 General: Provide canopies as shown and specified.

A. Standards: Materials and installation shall conform to the following:

1. AWS, D1.1 - Structural Welding Code - Steel

2. AMMA, Aluminum Finishes AAMA 2604 (FGIA 2604) - Powder Coat

B. Quality Assurance

1. Shop Drawings: To be created under the guidance of a professional engineer. Site Specific stamped drawing may be required by the manufacturer based on location. Drawings must indicate size, material and finish. Include plan, elevations and sections to clearly outline the canopy locations. Include installation procedures, details of joints, attachments and clearances.

a. Submit within 15 days after contract award.

2. Color charts showing manufacturer's full range of colors from standard line including Chipotle's custom "charcoal" color match to prototypical window mullion system.

2.1 Manufacturers:

A. Architectural Fabrication, Inc. – Manufacturer is located at 2100 E. Richmond Avenue, Fort Worth, TX 76104. P: (800) 962-8027. E: chipotle@arch-fab.com, W: www.arch-fab.com

B. Substitutions are acceptable assuming they comply with this specification, are submitted based on Quality Assurance and Division1 - Section 01100 requirements and have minimum 10 years experience, and only when approved by Arch PM and Chipotle DM.

1. Awnex, Contact: Katie Dicks, P: 770-704-7140 x151, E: katie@awnexinc.com

2. Uni-Structures, Contact: Dana Fredericks, P: 678-974-1773

3. API, Contact: Jade Moore-Esposto, P: 813-925-0144, E: jesposito@americanproducts.com

2.2 Materials:

A. Specifications are based on Architectural Fabrication, Inc. - Helios Canopy Patent #9,976,310

1. Framing: Gutter fascia, tube, angles: 6063-T6 alloy extruded aluminum. Gutter to be notched in the back to allow steel support arms to pass through.

2. Decking: Extruded aluminum 8" wide deck pan in 6063-T6 or 6063-T5 alloy (Roll form is not acceptable)

3. Steel Support Arms: 3" x 3" x .250" Steel tube support arms w/ 8" w x 5"h x 1/2" thick steel plate welded to the back. Must manufacture steel arm in manner to leave room for LED enclosure at back of canopy.

4. Hardware and Fasteners: Nuts, bolts, washers, clevis pins, screws, anchors and pipe spacers to be zinc plated or galvanized steel required to suit. application and per pre-engineered canopy load requirements. Typical wall anchors are minimum ½" diameter. Touch up paint must be provided for each canopy to allow for potential repairs in the field.

5. Flashing: Shall be minimum 0.040-inch aluminum, fabricated to prevent leakage and sealed with Novaflex metal roof sealant in custom color match. Another equivalent sealant is acceptable.

6. LED Enclosure: Each canopy is to have a preformed aluminum LED enclosure along the back edge of the canopy finished in the same powder coat as the canopy. 1" nominal inside width, and a minimum aluminum sheet thickness of .063".

7. Scuppers: Drainage for canopy is (2) aluminum scuppers located at the front of the canopy per drawings. See finish below for details.

8. Finish: All aluminum shall be powder coat finish per FGIA 2604 (aka AAMA 2604). Steel shall be commercially blasted, then coated with a zinc rich primer, and finally the top coat of super polyester powder (2604 compliant) applied.

3.1 Installation:

1. Install canopies per manufacturer's written instructions and videos, and as indicated on architectural drawings

2. Locate and place canopies level, plumb and at indicated alignment with adjacent work.

3. Use concealed anchors where possible.

4. Repair damaged finishes so no evidence remains of corrective work. Return items to the factory that cannot be refinished in the field. Make required alterations and refinish entire unit or provide new units.

5. Protect galvanized and nonferrous-metal surfaces from corrosion or galvanic action by applying a coating of bituminous paint or elastomeric coating on surfaces that will be in contact with concrete, masonry or dissimilar metals.

DIVISION 11- NOT APPLICABLE

DIVISION 12- FURNISHINGS

SECTION 12495 - WINDOW SHADES

1.1 General: Provide window shades as shown and specified.

A. Standards: Shade fabric material shall meet the requirements of the following:

1. NFPA 701 Flame Test and California US Title 19 for flame retardant materials.

B. Field measure window openings and verify installation conditions prior to window shade fabrication

C. Warranty:

1. 5 years against defects in materials and workmanship.

2. 1 year for service call repairs and adjustments.

2.1 Materials:

A. Manufacturer: Insolroll Window Shading Systems, Inc. (800) 447-5534, internet www.insolroll.com

B. Window Shades: Insolroll 2000 Solar Screen Shades, manual operation.

1. Solar Screen Shade Fabric: Insolroll woven fiberglass yarn, 5% openness, Charcoal/Bronze color.

2. Provide manufacturer's recommended mounting brackets and hardware.

C. Fabrication: Unless otherwise indicated, fabricate window shade units to completely fill existing window openings from jamb to jamb and from head to 42" AFF or the nearest horizontal mullion from 40"-44" AFF.

1. Adjustment system controlled by plastic bead chain on polyester cord. Multi-banded steel spring clutches keep shade in desired position.

2. Roller tube 2" extruded aluminum, sized to minimize deflection.

3. Fabric attached to roller tube using two-sided adhesive tape.

4. Fabric bottom hem RF heat sealed pocket with enclosed hem bar.

3.1 Installation:

A. Install window shades level and plumb in accordance with manufacturer's installation instructions and drawing details. Provide units securely anchored in place with recommended hardware and accessories to provide smooth operation without binding.

DIVISIONS 13 - 14 - NOT APPLICABLE

CONSULTANT:



CLIENT:




CHIPOTLE MEXICAN GRILL, INC.
P.O. BOX 162666
COLUMBUS, OH 43216-2666
TELEPHONE: (614) 316-2462
INTERNET: WWW.CHIPOTLE.COM

COPYRIGHT 2024
THIS DRAWING IS AN INSTRUMENT OF SERVICE AND AS SUCH REMAINS THE PROPERTY OF CHIPOTLE MEXICAN GRILL, INC.. PERMISSION FOR USE OF THIS DOCUMENT IS LIMITED AND CAN BE EXTENDED ONLY BY WRITTEN AGREEMENT WITH CHIPOTLE MEXICAN GRILL, INC..

PROJECT INFORMATION:

STORE NO.: 5037
HUNTLEY
12990 ROUTE 47, LOT 4B
HUNTLEY, IL 60142

SEAL:

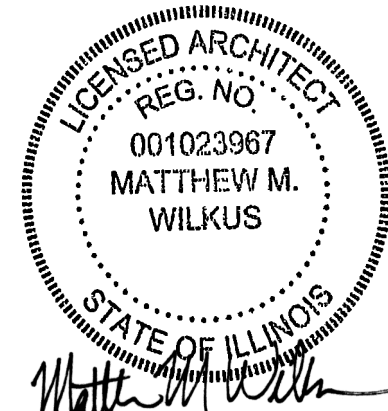

May 06, 2024

MATTHEW M. WILKUS
LICENSE #001.023967
(EXPIRES 11/30/2024)

PROJECT NO. 2023-0175
DRAWN BY JSB, DVA
CHECKED BY DVA, NSG, KAM, MMW

ISSUE RECORD:

02/12/2024 PERMIT SUBMITTAL
03/15/2024 BID SET
05/03/2024 CONSTRUCTION SET





REVISIONS:

TITLE:

ARCHITECTURAL SPECIFICATIONS

SHEET NUMBER:

G017

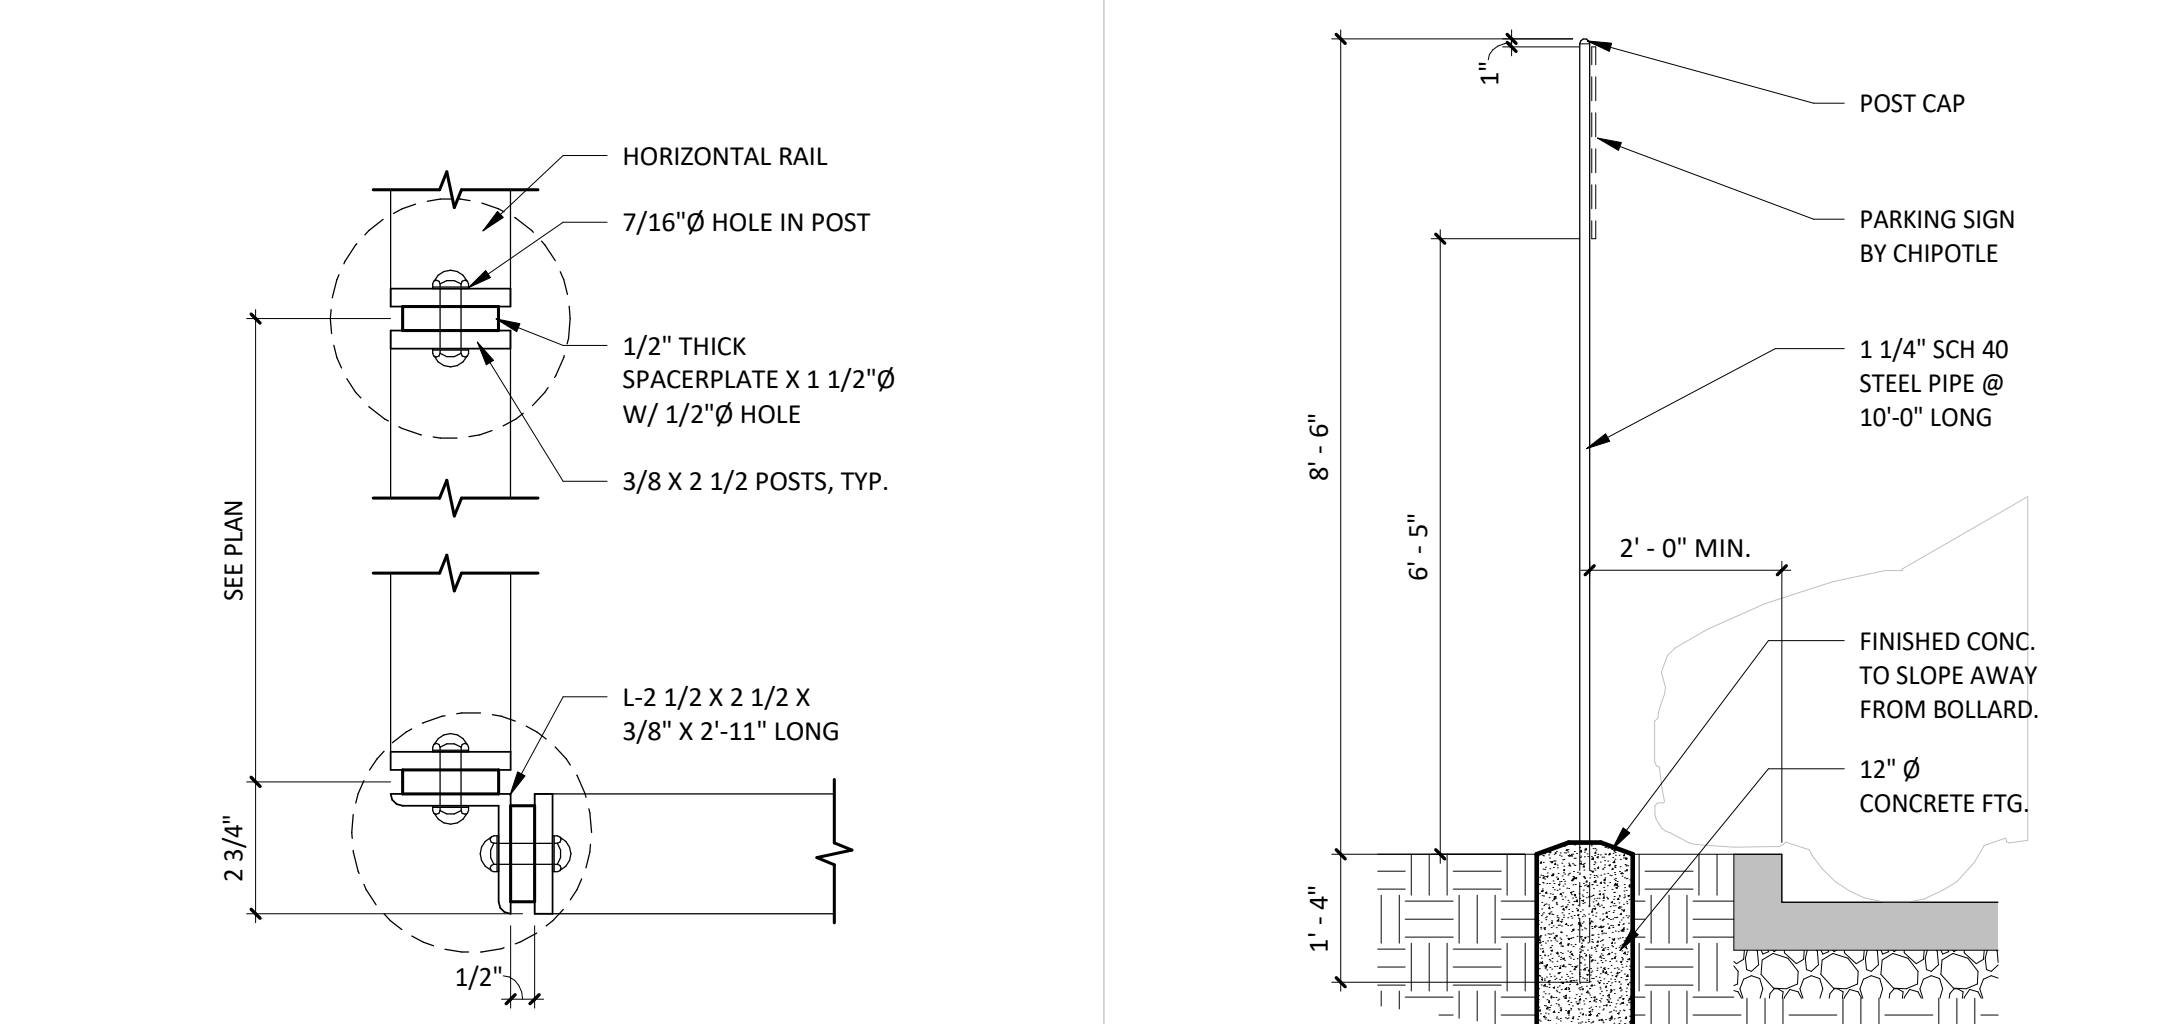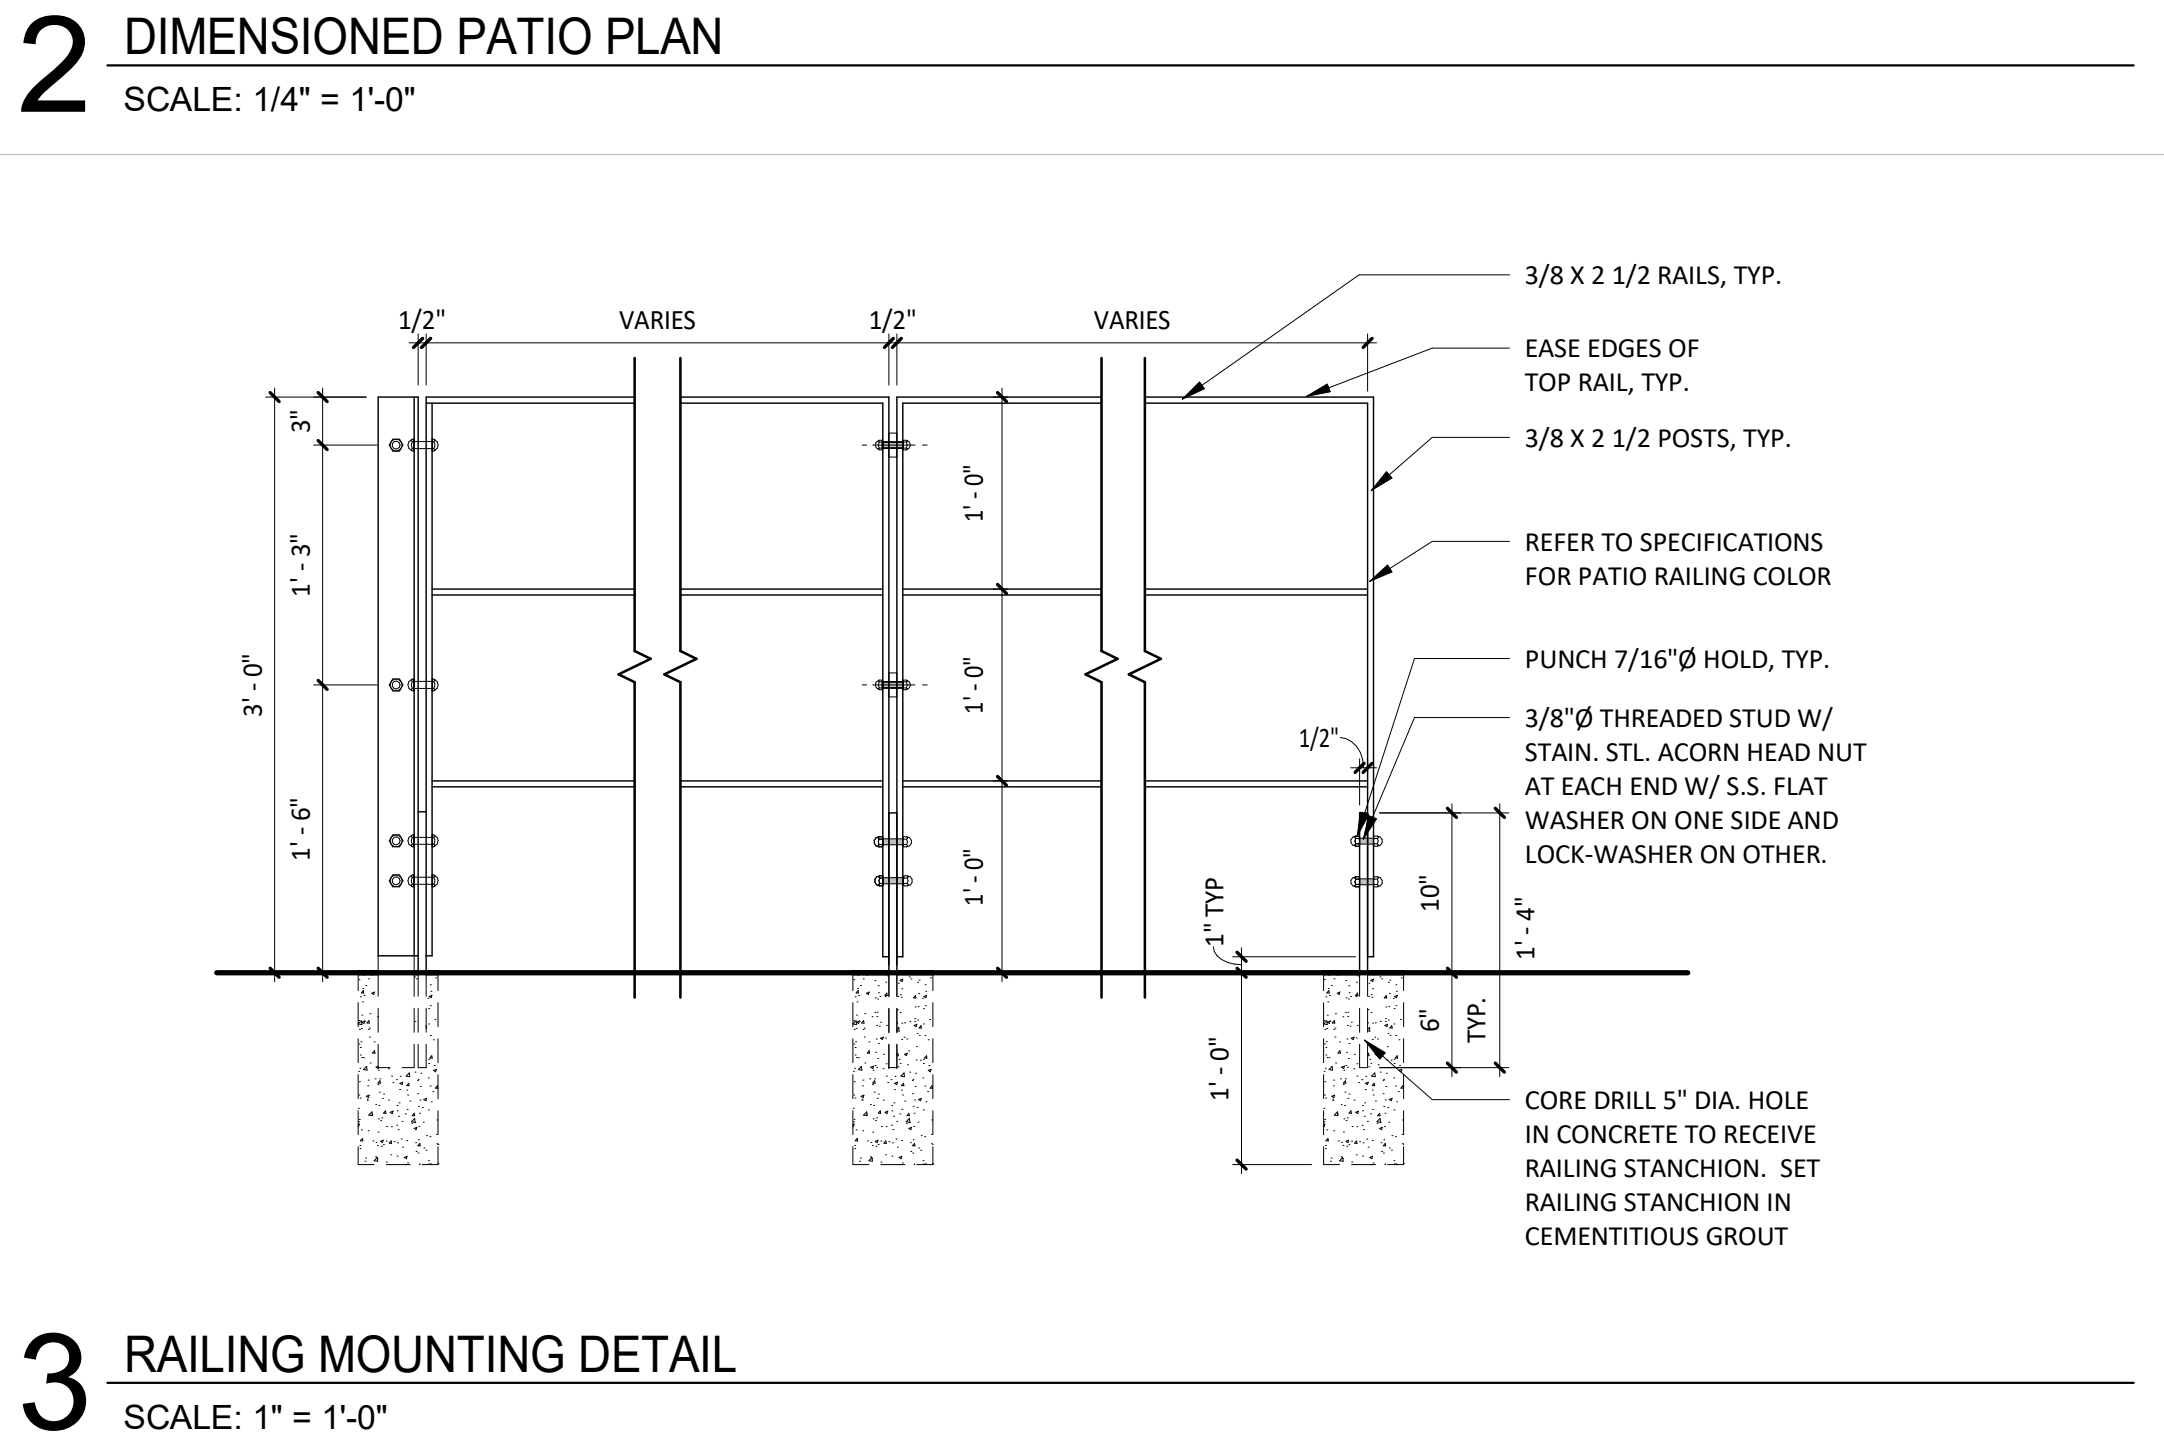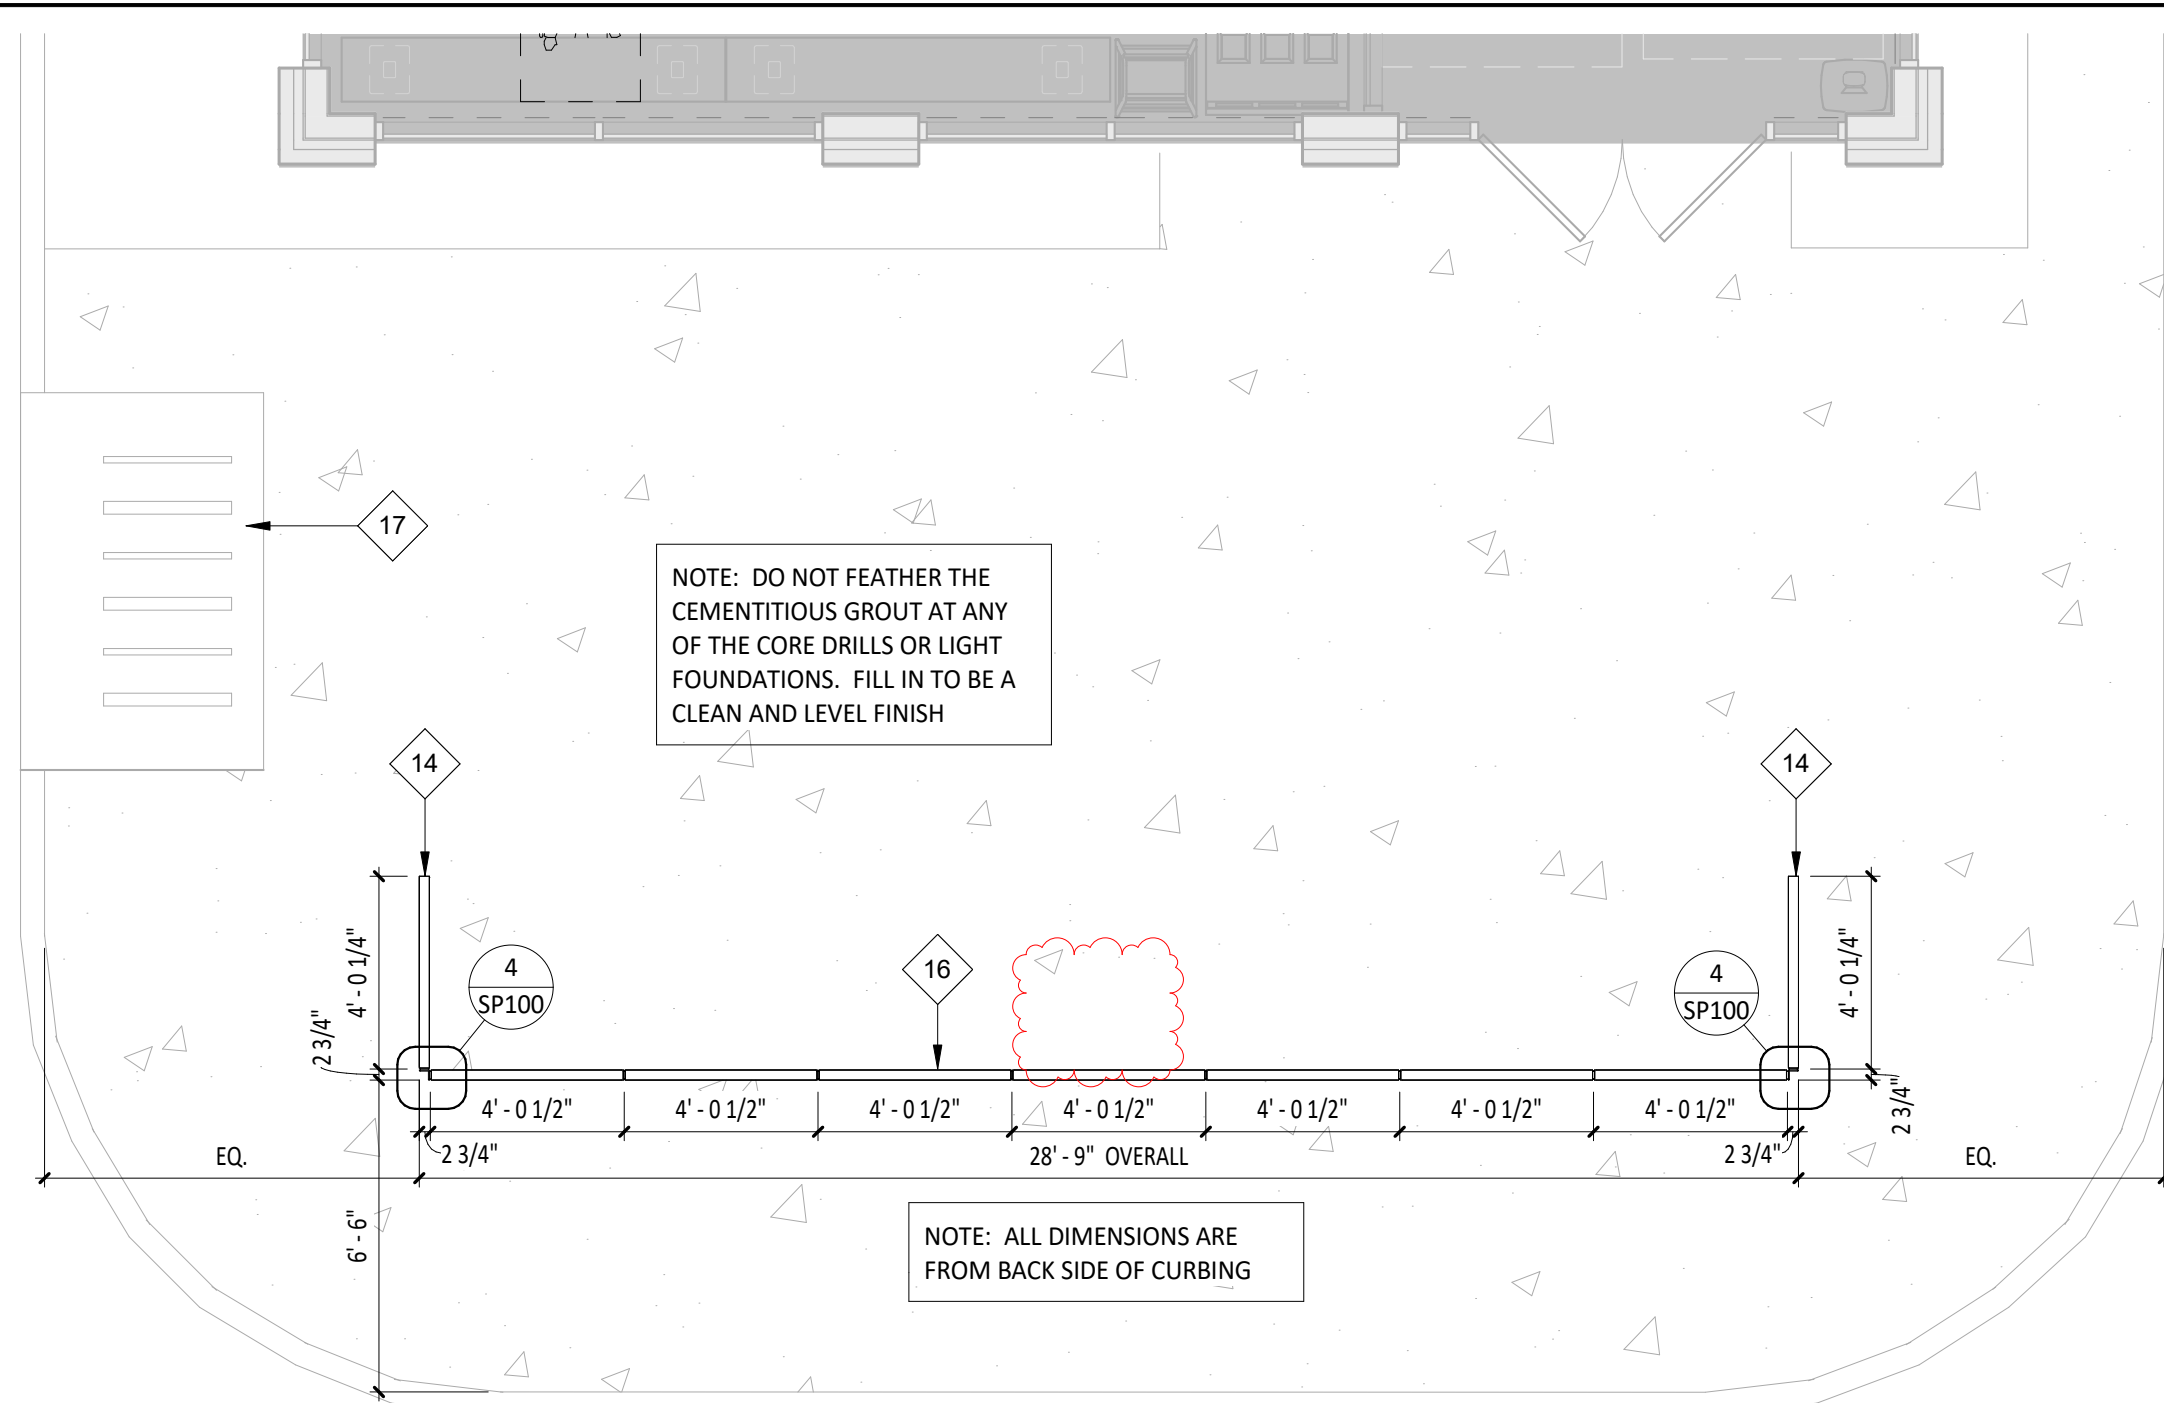
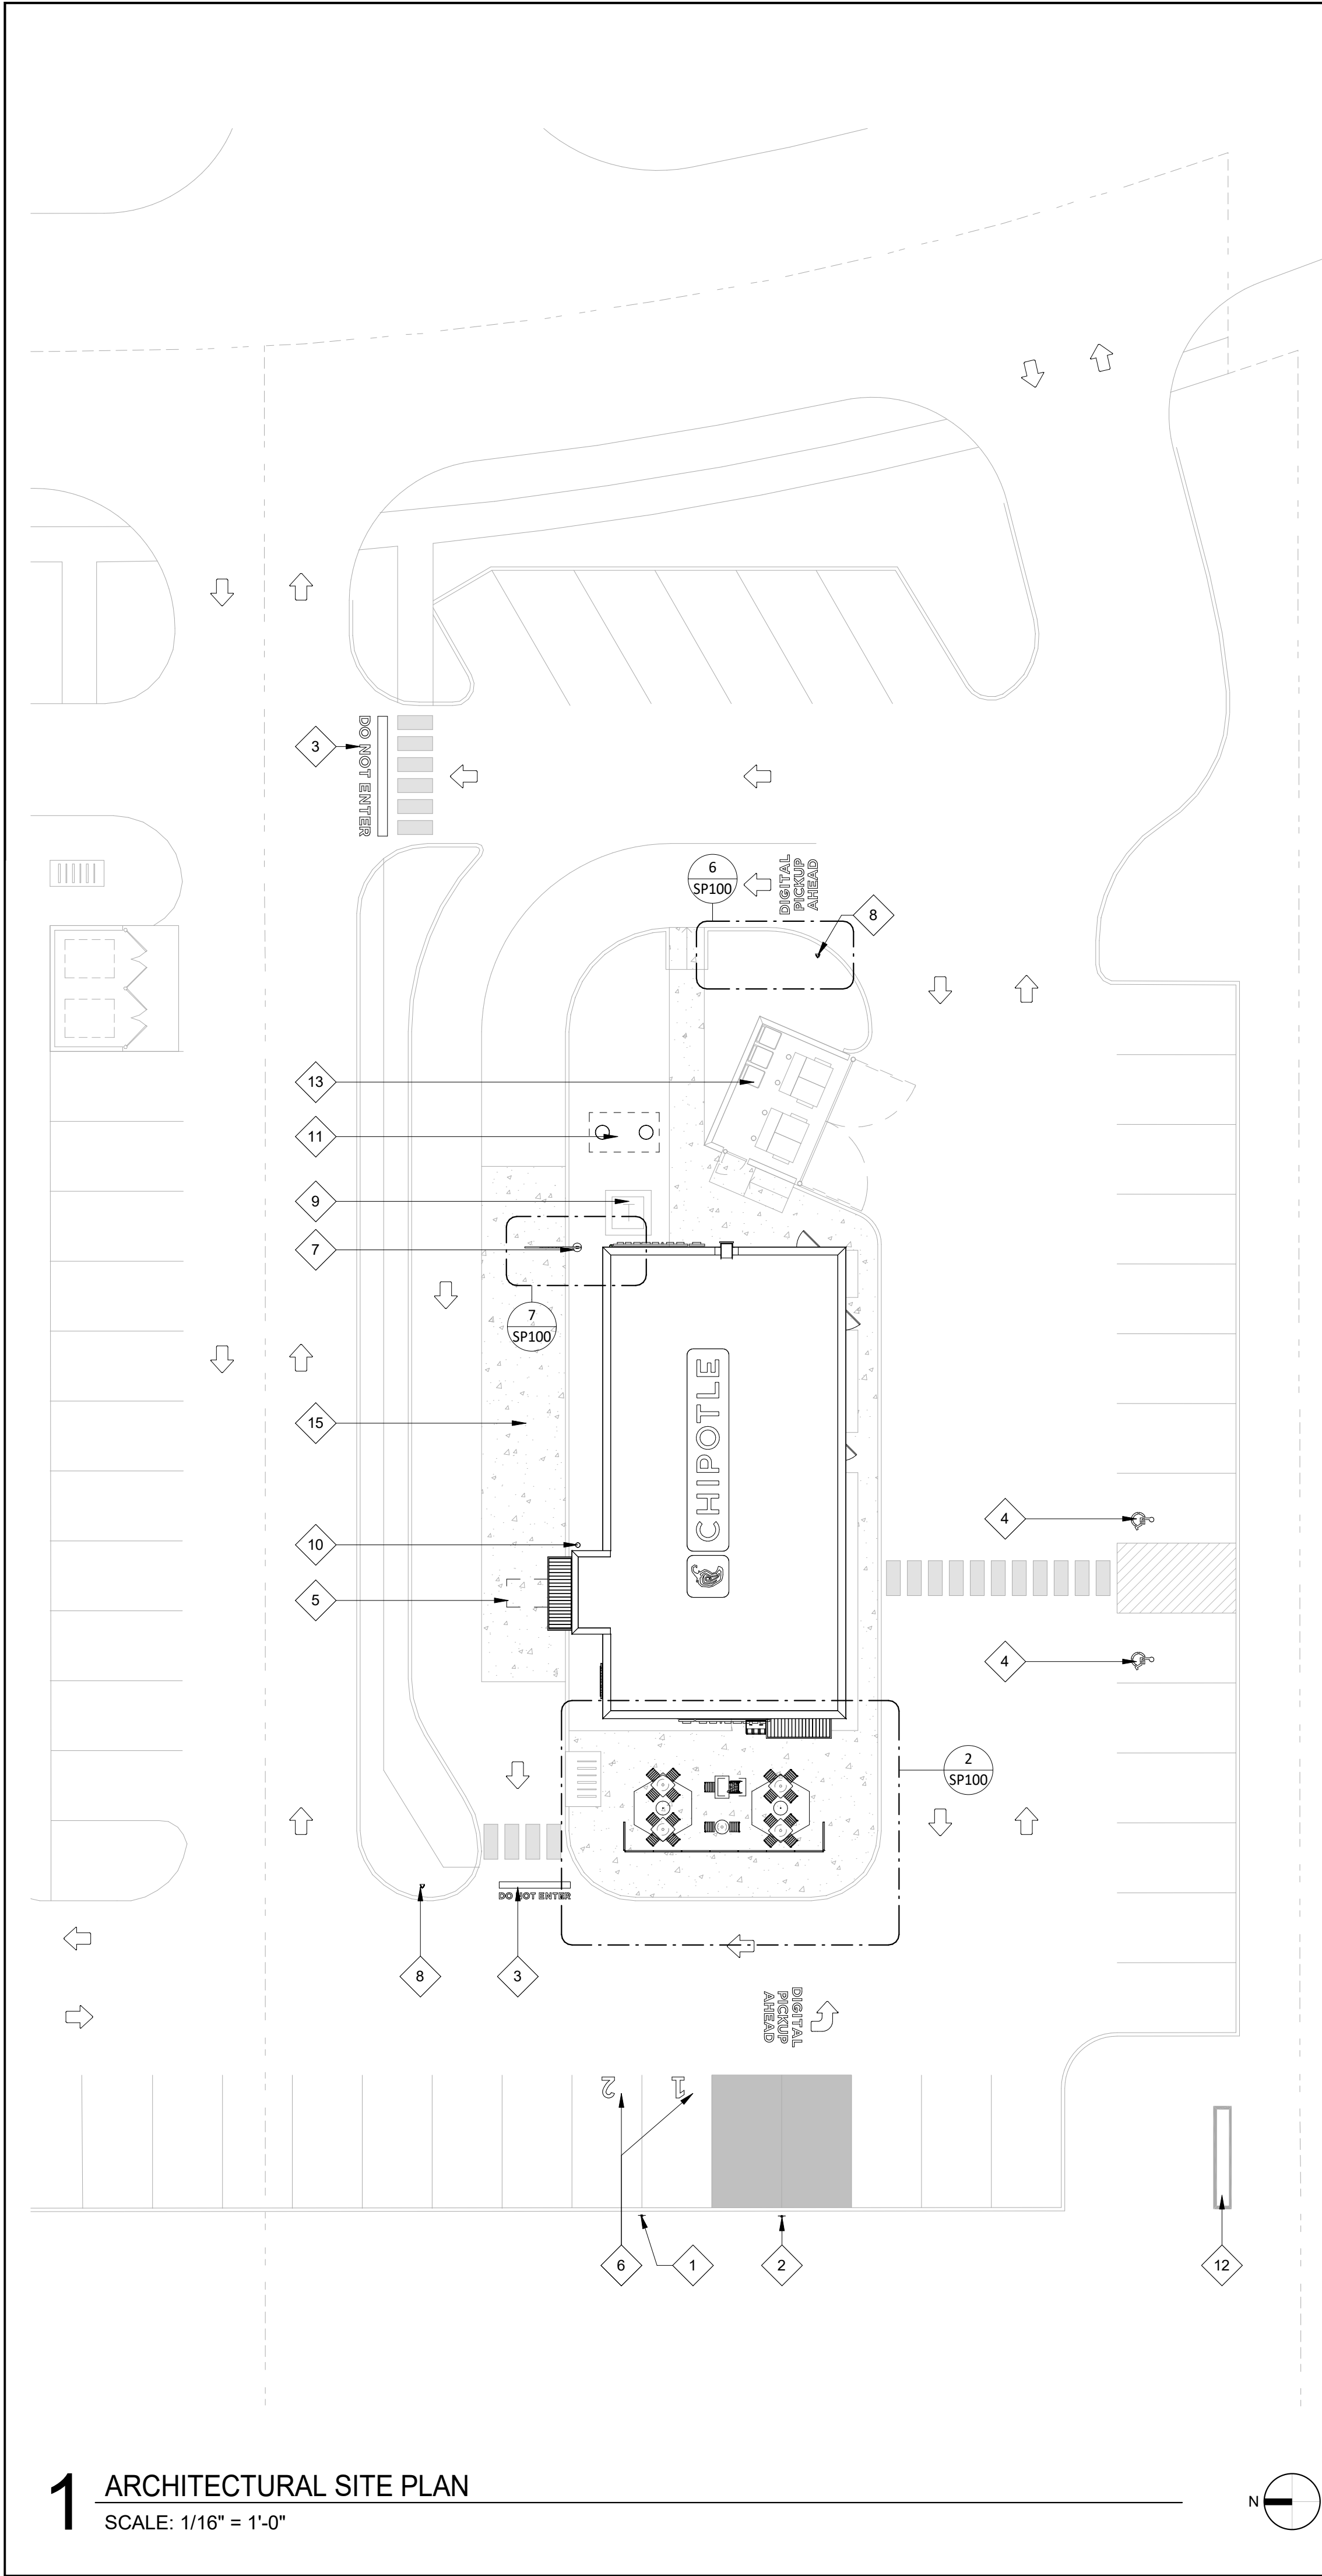


GENERAL NOTES - SITE PLAN

- ALL SITE WORK INCLUDING PAVING, CURBING, PARKING, PARKING LOT LIGHTING, SIDEWALKS, LANDSCAPING, BOLLARDS AND DUMPSTER ENCLOSURE ARE EXISTING UNLESS NOTED OTHERWISE.
- FOR STENCIL INFORMATION, REFER TO DIVISION 2 - SITE CONSTRUCTION FOR ADDITIONAL INFORMATION.
- PROVIDED ARCHITECTURAL SITE PLAN IS FOR REFERENCE PURPOSES ONLY. GENERAL CONTRACTOR TO VERIFY LANDLORD PROVIDED ITEMS MATCH THE INDICATED NOTING BELOW AS REQUIRED. IF GENERAL CONTRACTOR ENCOUNTERS ANY DISCREPANCIES, CONTACT THE ARCHITECT IMMEDIATELY.

KEYNOTE LEGEND

1	ONE (1) POLE SIGN WITH BOLLARD FOR PULL-AHEAD PARKING SPACES - FOUNDATION AND POLE BY GENERAL CONTRACTOR - SIGN PROVIDED BY TSV - INSTALLED BY GENERAL CONTRACTOR.
2	TWO (2) SPACES MARKED FOR 'BURRITO LOADING ZONE' PARKING - FOUNDATION AND POLE BY GENERAL CONTRACTOR - SIGN WITH BOLLARD PROVIDED BY TSV - INSTALLED BY GENERAL CONTRACTOR.
3	"DO NOT ENTER" AND "DIGITAL PICKUP AHEAD" AND DIRECTIONAL ARROWS PROVIDED BY LANDLORD.
4	TWO (2) ADA ACCESSIBLE PARKING SPACES MARKED WITH STRIPING AND SIGN POSTS - BY LANDLORD
5	LOOP DETECTOR INSTALLED BY CHIPOTLE'S GENERAL CONTRACTOR - REFER TO ELECTRICAL DRAWINGS FOR ADDITIONAL INFORMATION - CONDUIT STUB-UP PROVIDED BY LANDLORD.
6	TWO (2) PULL-AHEAD PARKING SPACES MARKED WITH WHITE NUMBERS PARALLEL TO STRIPING AND CENTERED IN SPACE - OFFSET NUMBERS INTO PARKING SPACE 12" MAX. FROM FRONT EDGE OF STRIPING.
7	CLEARANCE BAR AND FOUNDATION SUPPLIED AND INSTALLED BY TSV - REFER TO SP101 FOR ADDITIONAL INFORMATION.
8	DIGITAL PICKUP SIGN AND FOOTING (BY CHIPOTLE) CONDUIT AND STUB-UP (BY LANDLORD)
9	EXISTING TRANSFORMER LOCATION (BY LANDLORD).
10	EXISTING BOLLARD (BY LANDLORD).
11	1,500 GALLON GREASE INTERCEPTOR - FINAL LOCATION TBD - (BY LANDLORD)
12	MONUMENT SIGNAGE (LANDLORD) WITH SIGN PANELS EACH SIDE (BY CHIPOTLE)
13	TRASH ENCLOSURE, PAD, APRON AND BOLLARD (BY LANDLORD).
14	NO HOLES REQUIRED IN END POSTS, TYPICAL.
15	EXISTING CONCRETE DRIVE AISLE (BY LANDLORD).
16	PATIO RAILING PROVIDED BY CHIPOTLE.
17	EXISTING GROUND MOUNTED BIKE RACK (BY LANDLORD).

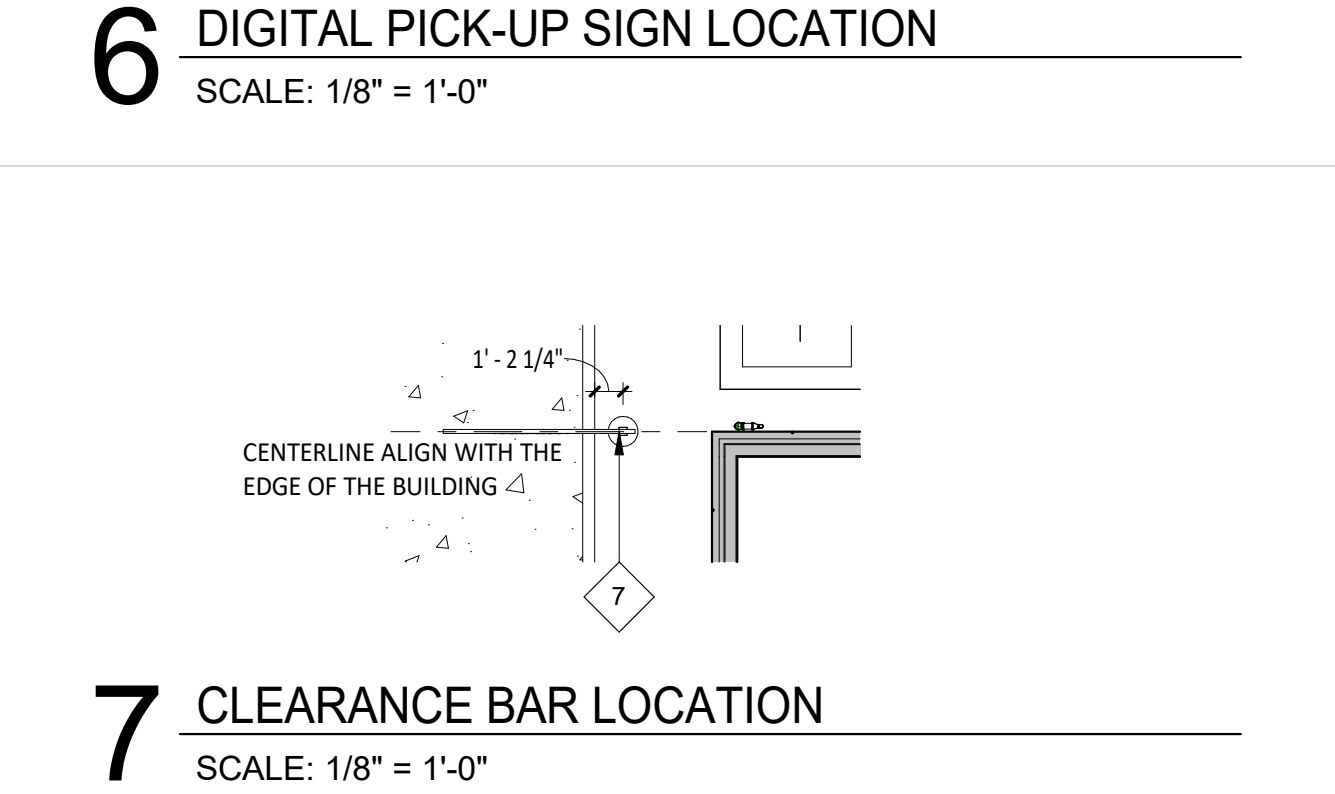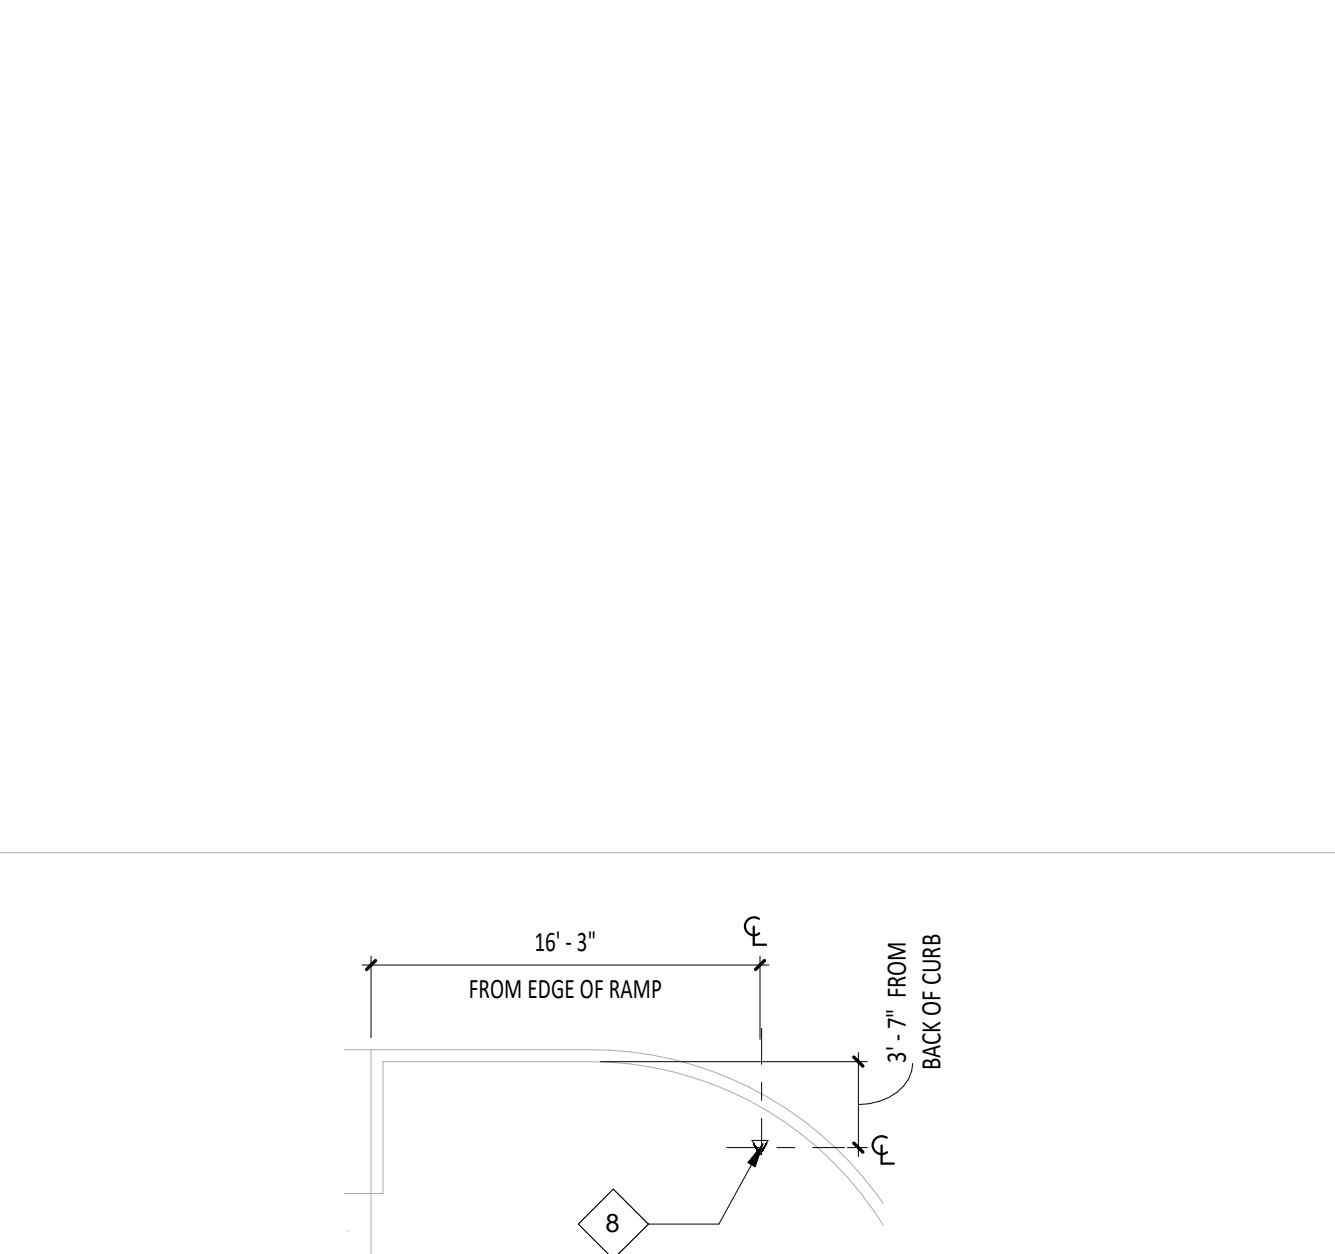

CONSULTANT:

WILKUS ARCHITECTS

CLIENT:

CHIPOTLE MEXICAN GRILL, INC.

CHIPOTLE MEXICAN GRILL, INC.
P.O. BOX 16266
COLUMBUS, OH 43216-2666
TELEPHONE: (614) 319-2482
INTERNET: WWW.CHIPOTLE.COM

COPYRIGHT 2024
THIS DRAWING IS AN INSTRUMENT OF SERVICE AND AS SUCH REMAINS THE PROPERTY OF CHIPOTLE MEXICAN GRILL, INC. PERMISSION FOR USE OF THIS DOCUMENT IS LIMITED AND CAN BE EXTENDED ONLY BY WRITTEN AGREEMENT WITH CHIPOTLE MEXICAN GRILL, INC.

PROJECT INFORMATION:

STORE NO.: 5037
HUNTLEY
12990 ROUTE 47, LOT 4B
HUNTLEY, IL 60142

SEAL:

LICENSED ARCHITECT
REG. NO. 001023967
MATTHEW M. WILKUS
STATE OF ILLINOIS
May 06, 2024
MATTHEW M. WILKUS
LICENSE #001.023967
(EXPIRES 11/30/2024)

PROJECT NO. 2023-0175
DRAWN BY JSB, DVA
CHECKED BY DVA, NSG, KAM, MMW

ISSUE RECORD:

02/12/2024	PERMIT SUBMITTAL
03/15/2024	BID SET
05/03/2024	CONSTRUCTION SET

REVISIONS:





2	03.15.2024	CITY COMMENTS
---	------------	---------------

TITLE:

SITE PLAN

SHEET NUMBER:

SP100

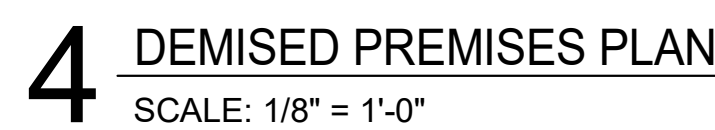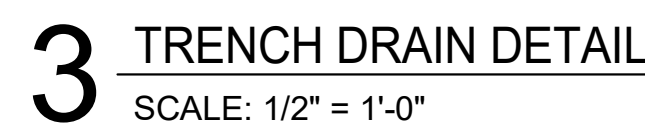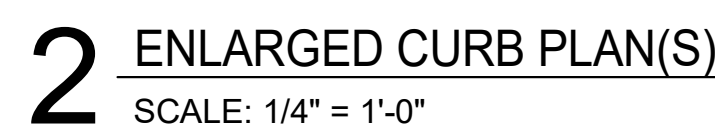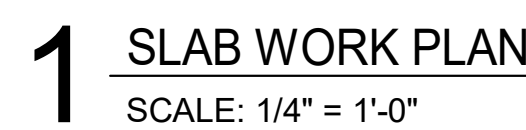

1	4" PVC PIPE WITH 2" HIGH CONCRETE INFILL FOR POWER STUBS - TYPICAL OF TWO (2) - REFER TO ELECTRICAL DRAWINGS FOR ADDITIONAL INFORMATION.
2	OUTLINE OF MOP SINK AS INDICATED.
3	TRENCH DRAIN TO BE RECESSED INTO SLAB A MINIMUM OF 8" THICK CONCRETE SLAB WITH 4" MINIMUM CONCRETE BED BELOW - REFER TO MANUFACTURER'S INSTALLATION INSTRUCTIONS - SEE DETAIL 3/A101 FOR ADDITIONAL INFORMATION - SLOPE FLOOR IN THIS AREA ONLY TOWARDS DRAIN 1/40.
4	5" X 5" POWER STUB LOCATION - COORDINATE WITH ELECTRICAL PLANS FOR ADDITIONAL INFORMATION.
5	LANDLORD TO PROVIDE POROUS FILL - CHIPOTLE GENERAL CONTRACTOR TO PROVIDE 10 MIL VAPOR BARRIER AND 4" MINIMUM CONCRETE SLAB ON GRADE - REFER TO STRUCTURAL DRAWINGS FOR ADDITIONAL INFORMATION.
6	4" CONCRETE CURB - COORDINATE EXACT LOCATION WITH FINAL EQUIPMENT LOCATIONS - SEE DETAILS 1/A801 FOR ADDITIONAL INFORMATION.

PROJECT INFORMATION:

STORE NO.: 5037
HUNTLEY
12990 ROUTE 47, LOT 4B
HUNTLEY, IL 60142

SEAL

LICENSED ARCHITECT
RES. NO.
001023967
MATTHEW M.
WILKUS
STATE OF ILLINOIS

Matthew M. Wilkus

May 06, 2024

MATTHEW M. WILKUS
LICENSE #001023967
(EXPIRES 11/30/2024)

PROJECT NO. 2023-0175
DRAWN BY JSB, DVA
CHECKED BY DVA, NSG, KAM, MMW

ISSUE RECORD:	
02/12/2024	PERMIT SUBMITTAL
03/15/2024	BID SET
05/03/2024	CONSTRUCTION SET

REVISIONS: _____

TITLE:

SLAB WORK PLAN

SHEET NUMBER:

A101

WALL TYPE LEGEND


NEW CONSTRUCTION		INDICATES LOCATION OF ITEMS ABOVE	
EXISTING CONSTRUCTION		DESIGNATES WALLS & SHEATHING TO EXTEND TO DECK	
NEW CONSTRUCTION WITH SOUND BATT INSULATION			
WALK-IN COOLER			

GENERAL NOTES - FLOOR PLAN


- ALL DIMENSIONS ARE TO FACE OF FRAMING, OR CENTERLINE OF STRUCTURE UNLESS NOTED OTHERWISE.
- ALL DIMENSIONS TO EXTERIOR OR EXISTING WALLS ARE TO THE FINISH FACE OF THE EXISTING GYP. BD.
- DASHED CIRCLE IN RESTROOM INDICATES 5'-0" TURNING DIAMETER REQUIRED BY ADA.
- REFER TO WALL FINISH LEGEND ON A120.
- IN SITUATIONS WHERE TENANT'S G.C. IS TO PROVIDE TYPE 'X' GYP. BD. FOR A RATED ASSEMBLY, THE TYPE 'X' GYP. BD. IS REQUIRED TO GO BENEATH THE SHEATHING AND FINISHES.
- SEE SHEET A801 FOR ADDITIONAL SHEATHING BEHIND CERTAIN WALL FINISHES.
- SEE A601 FOR DOOR TYPES.
- TENANT'S GENERAL CONTRACTOR TO PERFORM LAYOUT OF ENTIRE SPACE PRIOR TO STARTING FRAMING AND REPORT ANY DISCREPANCIES IN NOTED DIMENSIONS TO ARCHITECT AND CHIPOTLE MEXICAN GRILL'S CM PRIOR TO PROCEEDING. FAILURE TO ADHERE TO THESE REQUIREMENTS RESULTING IN ANY REMEDIATION REQUIRED TO MEET DESIGN INTENT WILL BE AT CONTRACTOR'S COST.
- PROVIDE FULL HEIGHT BLOCKING IN WALL FOR ALL SHELVING, TYP.
- DENSSHIELD TILE BACKER BOARD SHALL NOT BE INSTALLED OVER VAPOR BARRIERS AT EXTERIOR WALLS.
- MOISTURE RESISTANT GYP. BD. SHALL BE USED IN RESTROOMS.
- ALL STUDS ARE 3 5/8" METAL STUDS UNLESS NOTED OTHERWISE ON PLAN.
- ALL INTERIOR DOORS ARE 4" OFF OF PERPENDICULAR WALL UNLESS NOTED OTHERWISE.

KEYNOTE LEGEND


- WHERE GREASE EXHAUST HOOD INTERSECTS WALLS, PROVIDE 24 GAUGE GALVANIZED METAL FROM TOP OF WALL TO 18" PAST HOOD IN ALL DIRECTIONS.
- FOR ALL REQUIRED BLOCKING LOCATIONS, REFER TO ELEVATIONS ON A710.
- LOCATION OF WALL PASS-THROUGH OPENING - REFER TO A702.
- SUBSTRATE FACE TO ALIGN.
- DRYER VENTS IN WALL FOR SODA LINES ROUTED ABOVE 4" PVC PIPES - REFER TO A801 FOR ADDITIONAL INFORMATION.
- PROVIDE MOUNTING BOARDS FOR SECURITY SYSTEMS AND TELECOMS - REFER TO ELECTRICAL DRAWINGS FOR ADDITIONAL INFORMATION.
- DASHED LINES INDICATE LOCATION OF SOFFIT WALL TO DECK ABOVE - REFER TO A201 FOR ADDITIONAL INFORMATION.
- DASHED LINES INDICATE LOCATION OF SOFFIT ABOVE - REFER TO A201 FOR ADDITIONAL INFORMATION.
- DASHED LINES INDICATE LOCATION OF HEADER ABOVE - REFER TO A201 FOR ADDITIONAL INFORMATION.
- HATCHED AREAS INDICATED FRAMING TO STOP AT 10'-0" A.F.F.
- FOR LOCATION OF LOW-WALL CONDITION AT MOPUS - REFER TO A502, A701 AND A702.
- PROVIDE IN-WALL BLOCKING FOR LICENSE FRAME AS REQUIRED.
- PROVIDE 25 GAUGE GLAVANIZED METAL TO 50 1/2" A.F.F.

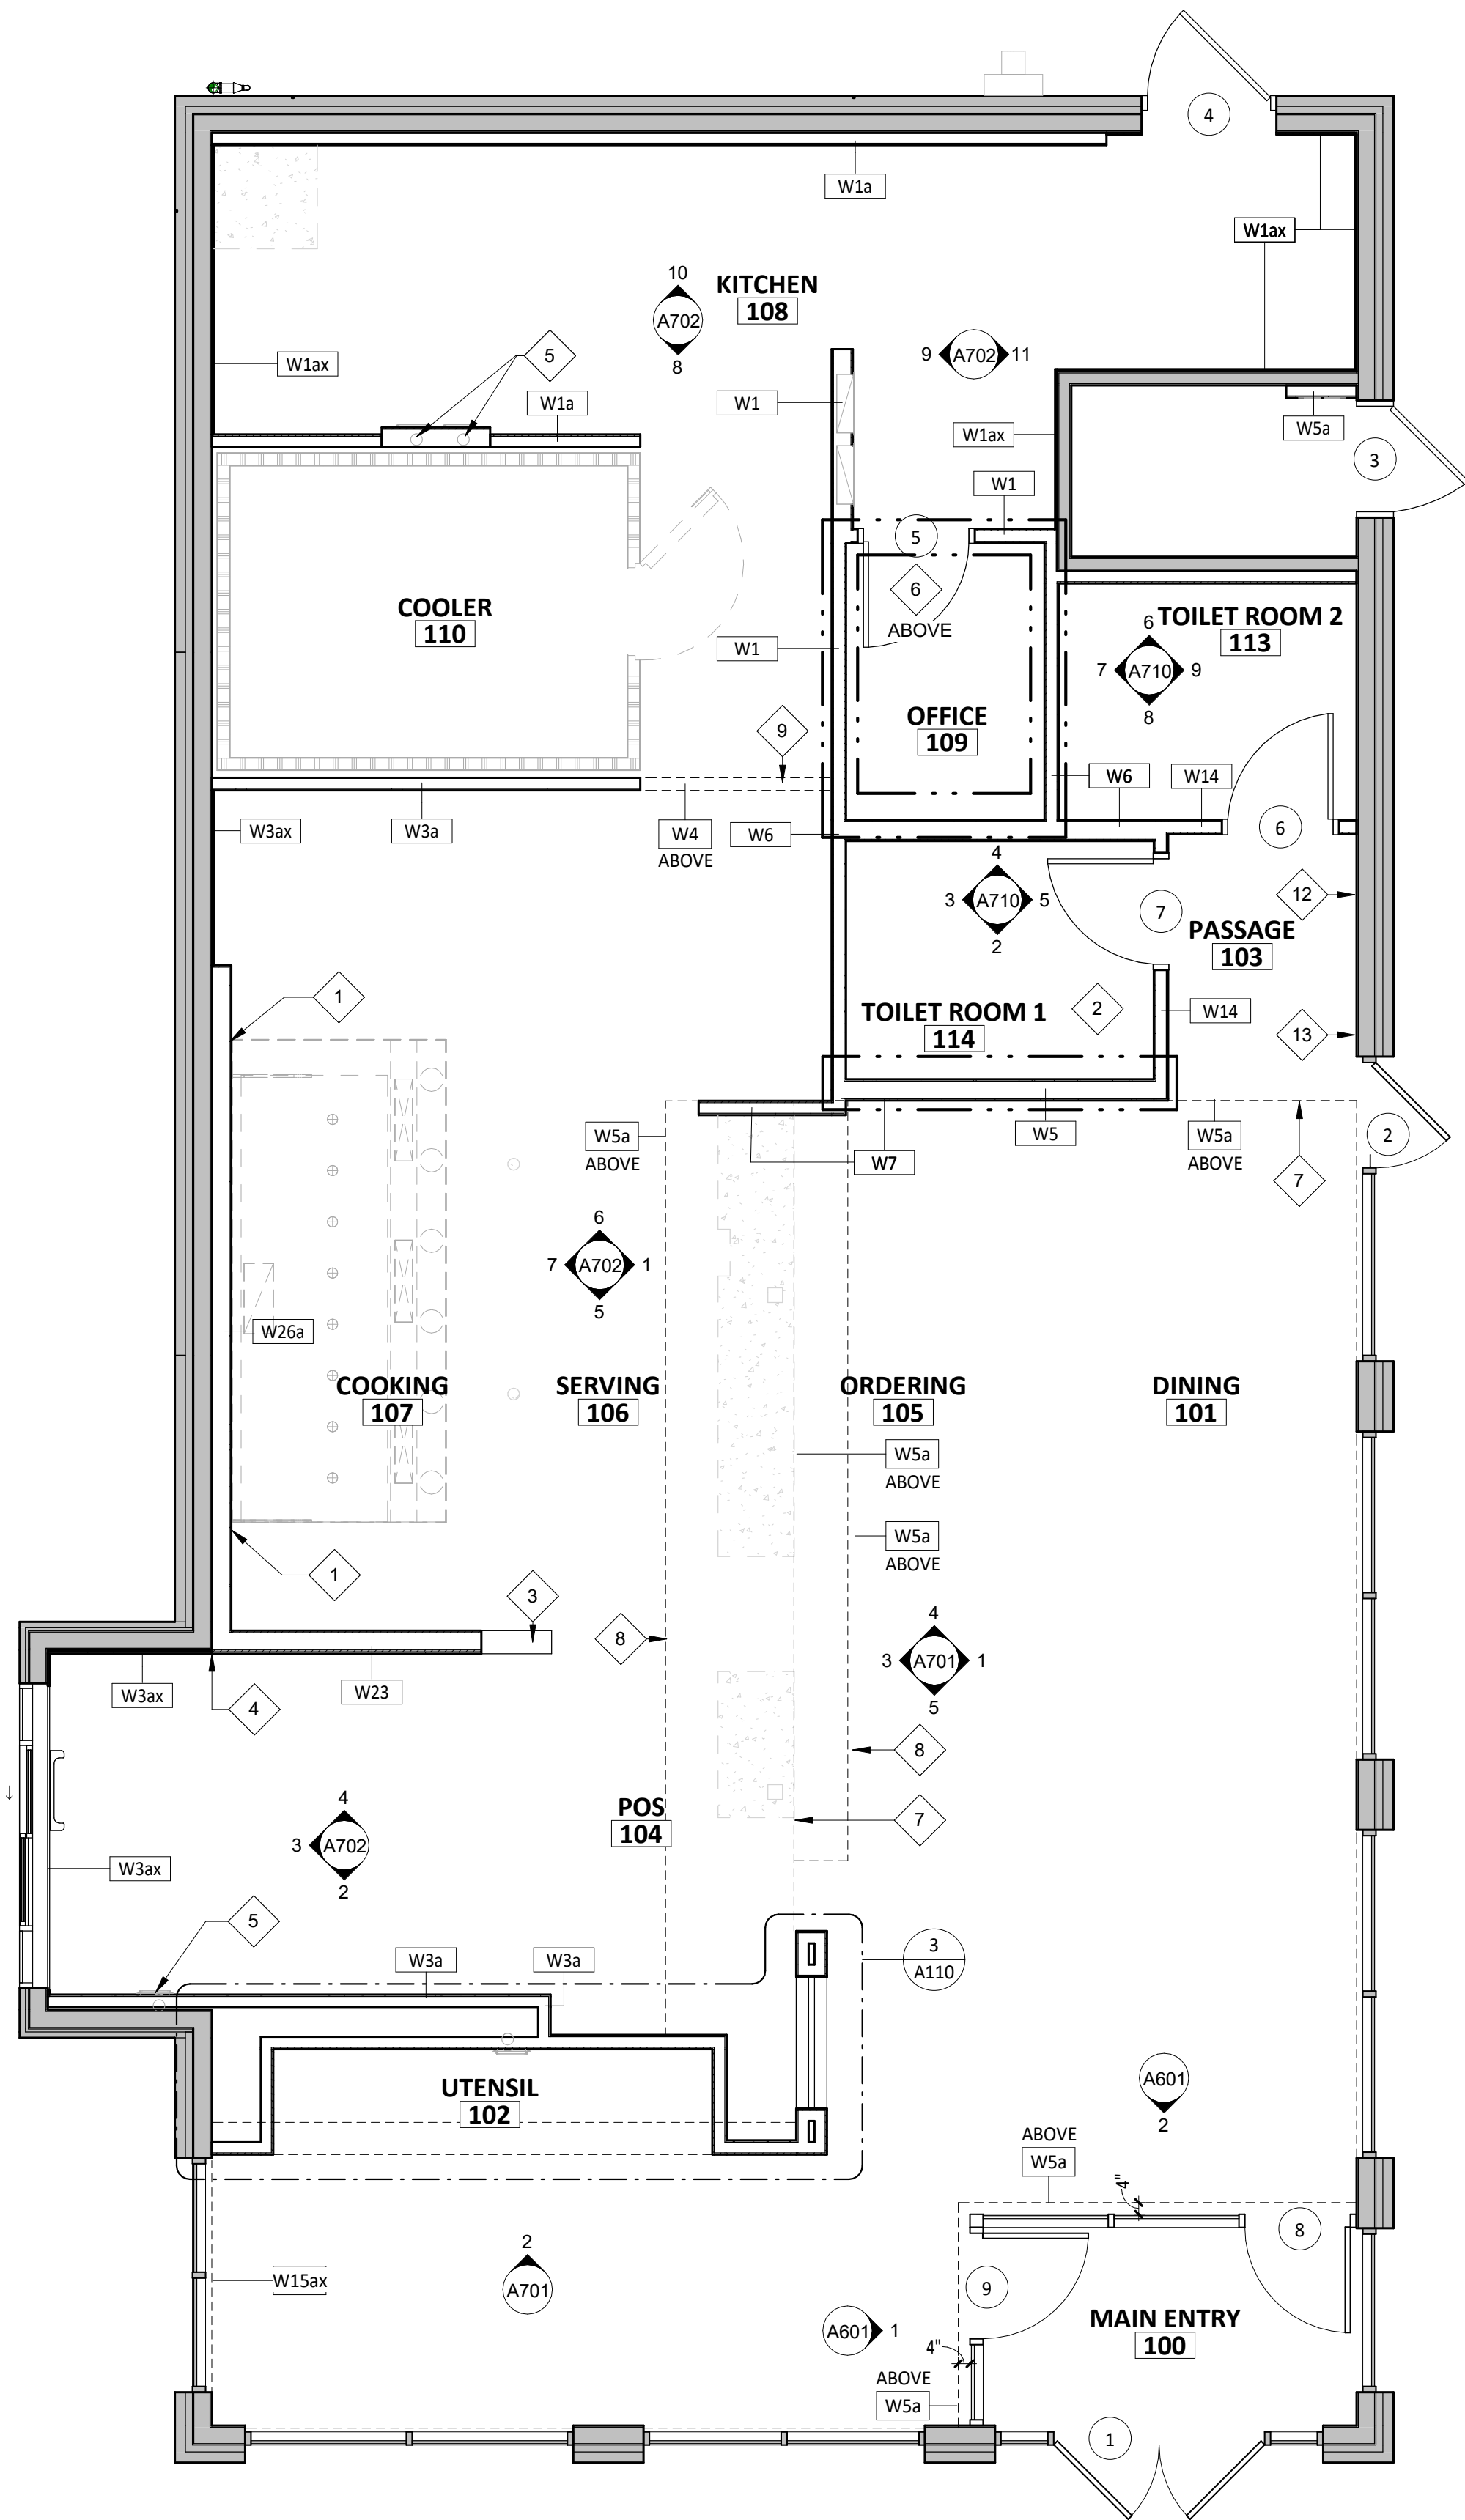

1 ARCHITECTURAL FLOOR PLAN
SCALE: 1/4" = 1'-0"

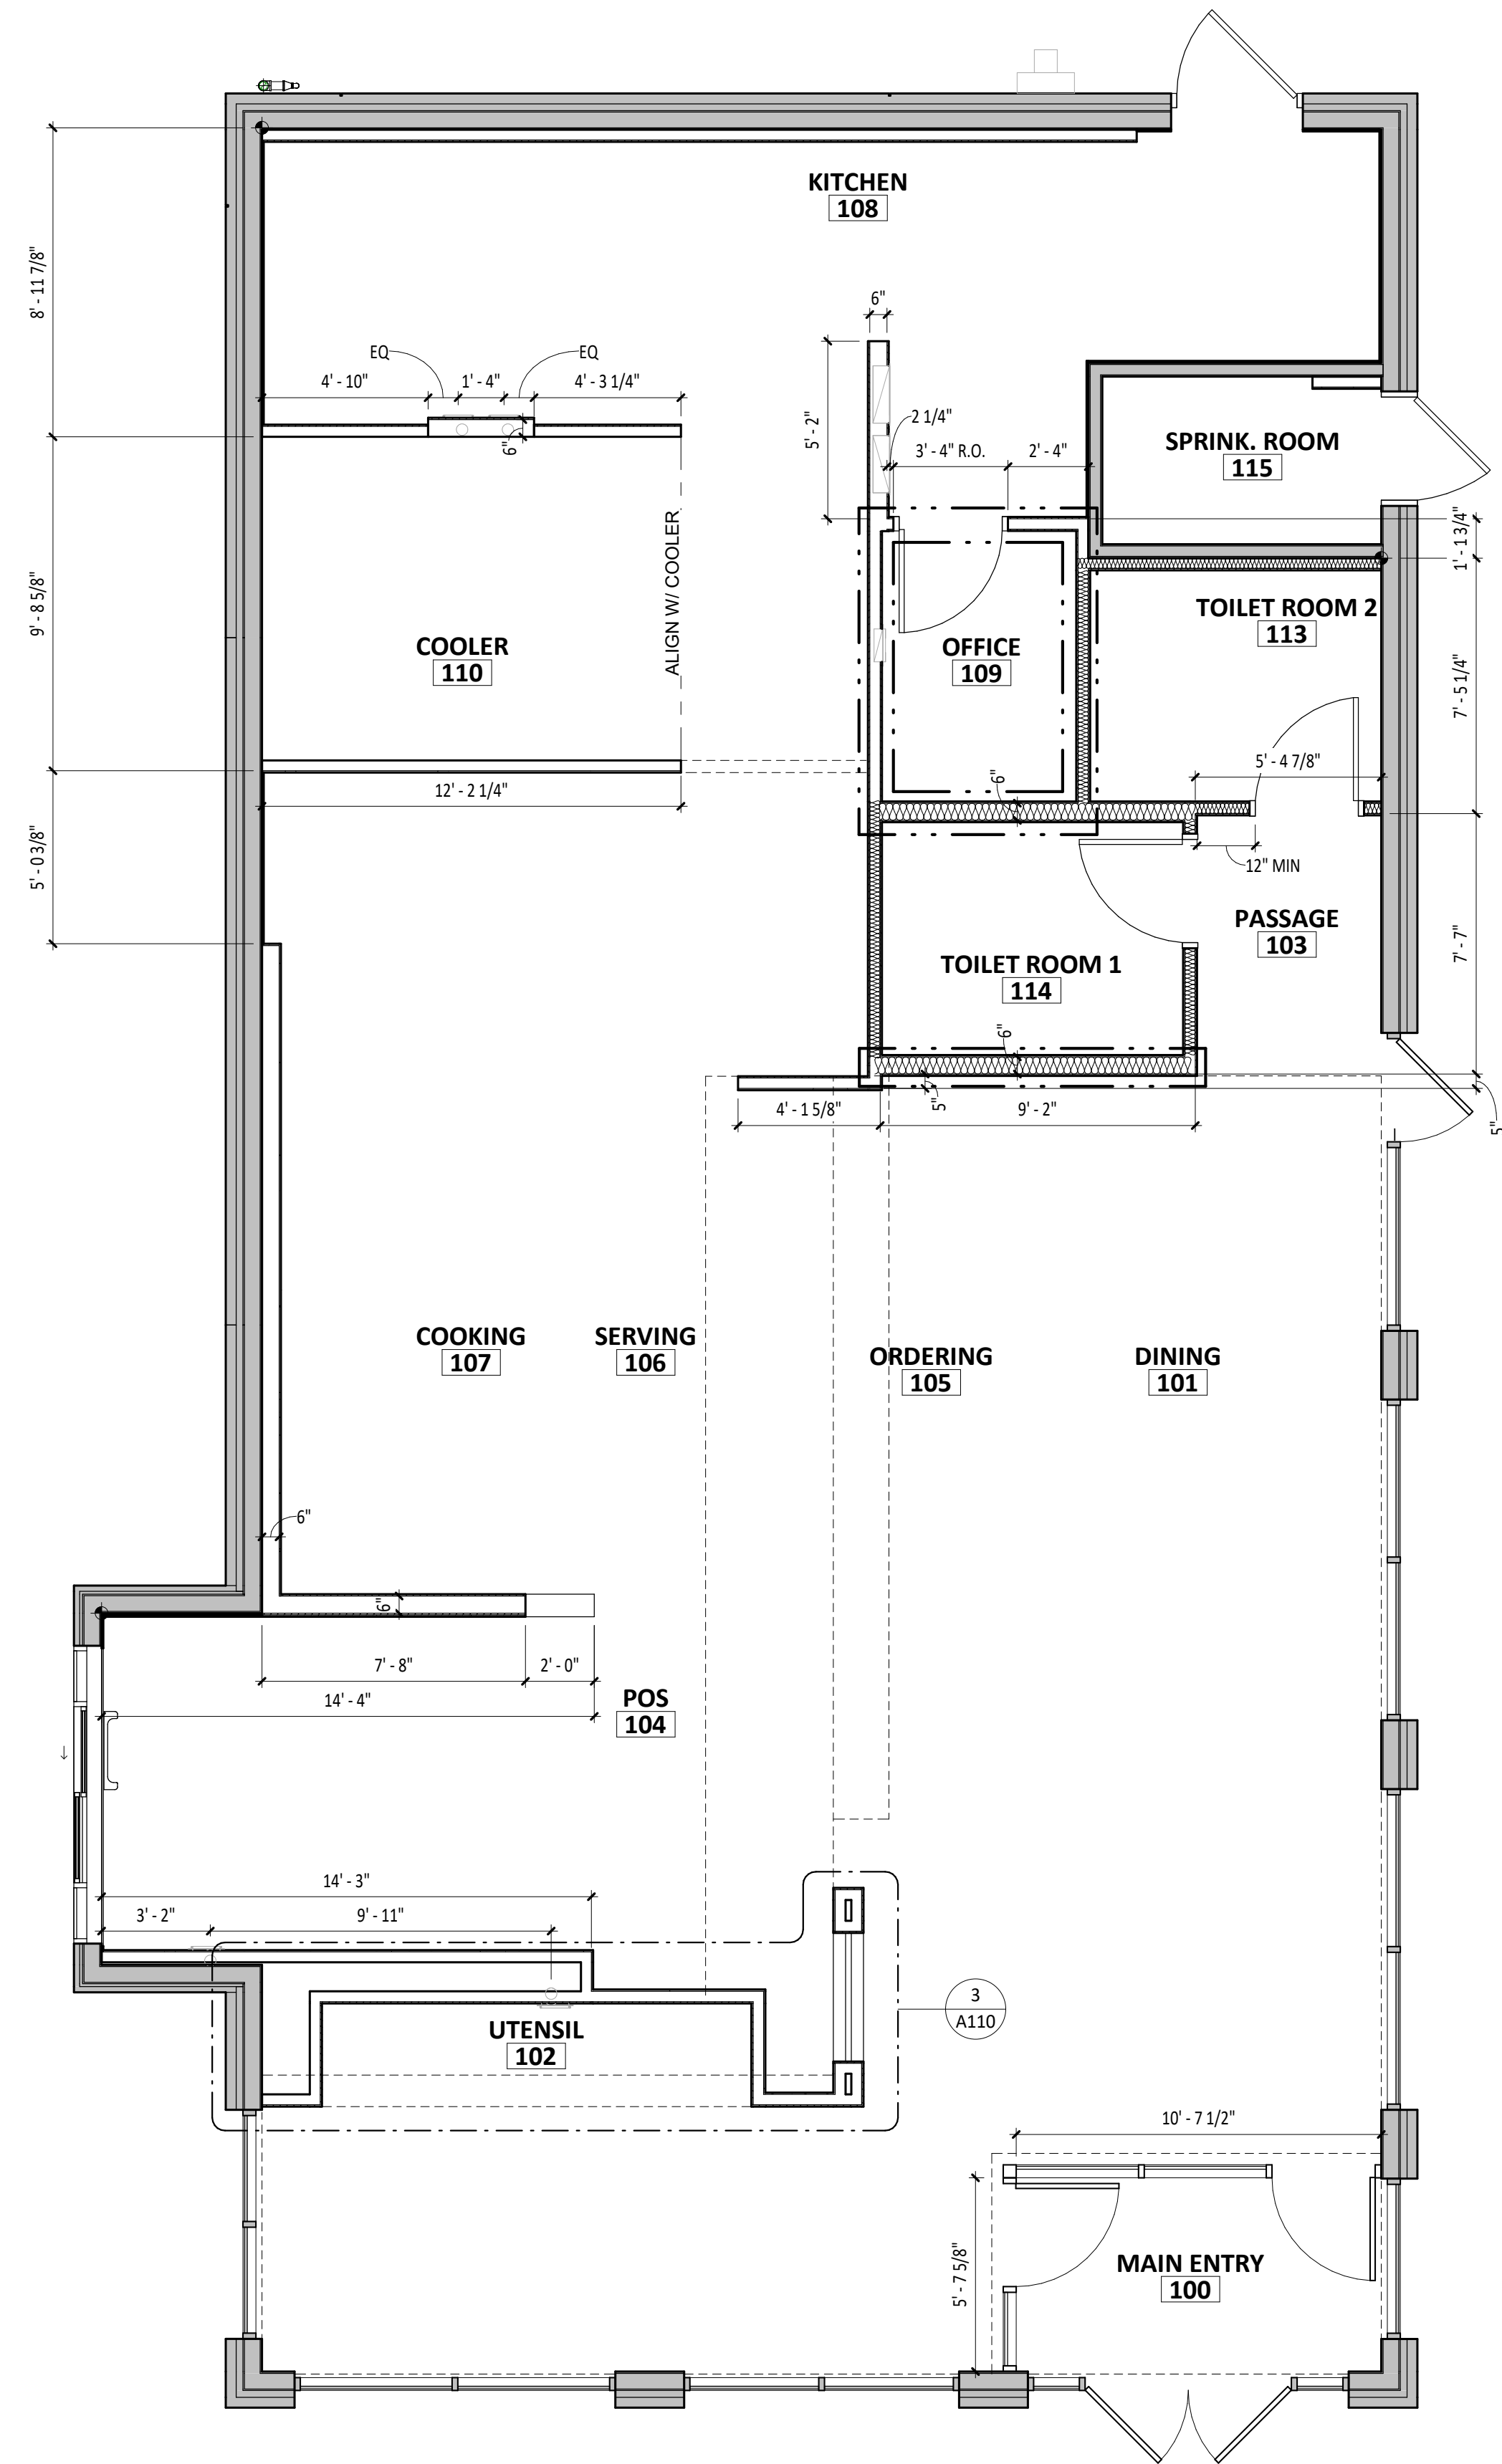

2 DIMENSIONED FLOOR PLAN
SCALE: 1/4" = 1'-0"

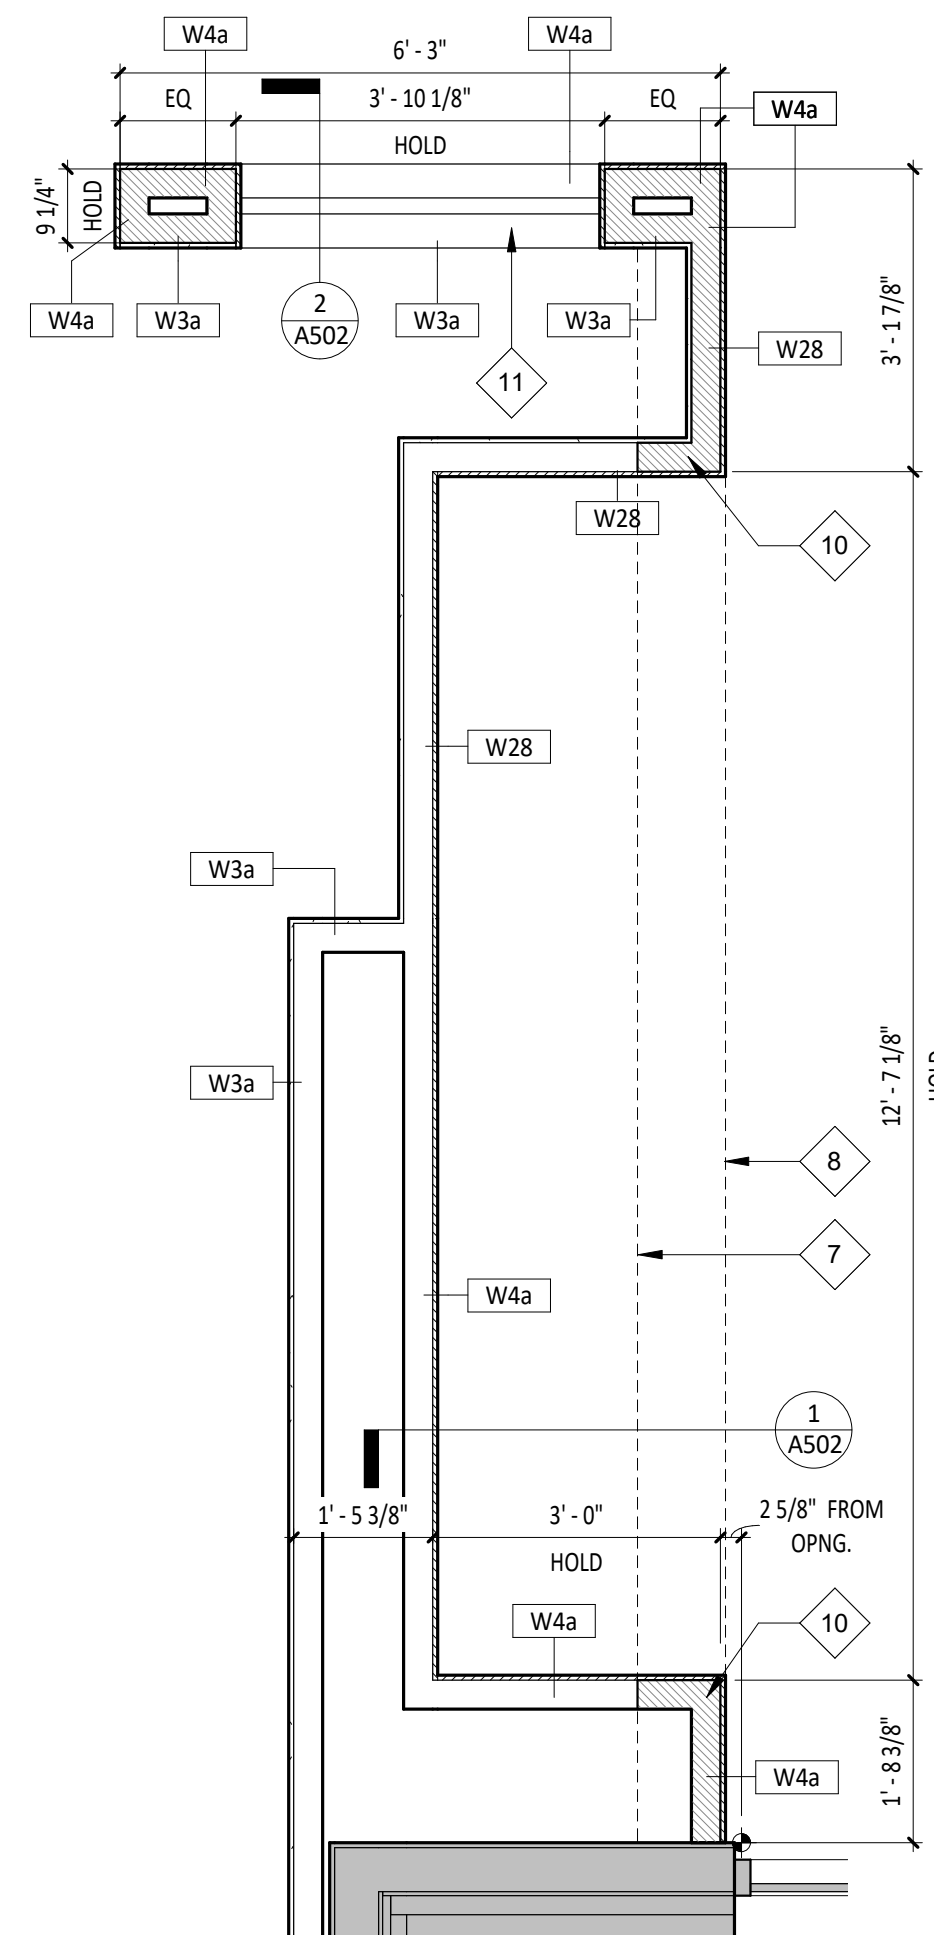

3 ENLARGED UTENSIL/MOPUS PLAN
SCALE: 1/2" = 1'-0"

CONSULTANT:



CLIENT:




COPYRIGHT 2024
THIS DRAWING IS AN INSTRUMENT OF SERVICE AND
AS SUCH REMAINS THE PROPERTY OF CHIPOTLE
MEXICAN GRILL, INC. PERMISSION FOR USE OF THIS
DOCUMENT IS LIMITED AND CAN BE EXTENDED ONLY
BY WRITTEN AGREEMENT WITH CHIPOTLE MEXICAN
GRILL, INC.

PROJECT INFORMATION:

STORE NO.: 5037
HUNTLEY
12990 ROUTE 47, LOT 4B
HUNTLEY, IL 60142

SEAL:

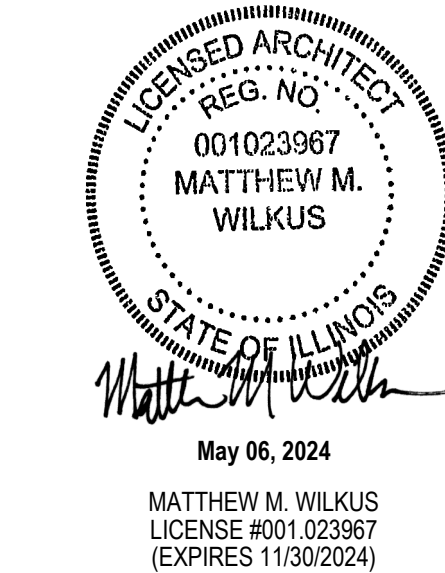

PROJECT NO. 2023-0175
DRAWN BY JSB, DVA
CHECKED BY DVA, NSG, KAM, MMW

ISSUE RECORD:
02/12/2024 PERMIT SUBMITTAL
03/15/2024 BID SET
05/03/2024 CONSTRUCTION SET


REVISIONS:

TITLE:


ARCHITECTURAL
FLOOR PLAN

SHEET NUMBER:

A110

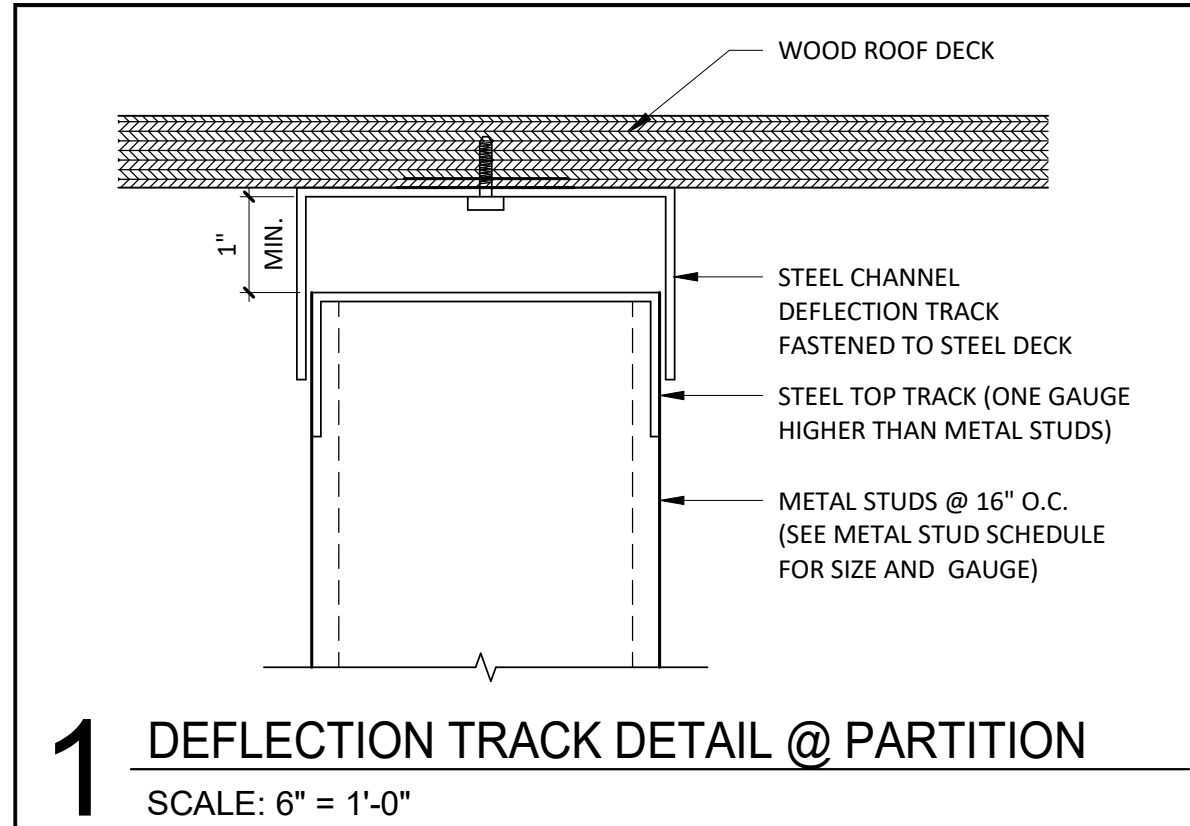


1 DEFLECTION TRACK DETAIL @ PARTITION
SCALE: 6" = 1'-0"

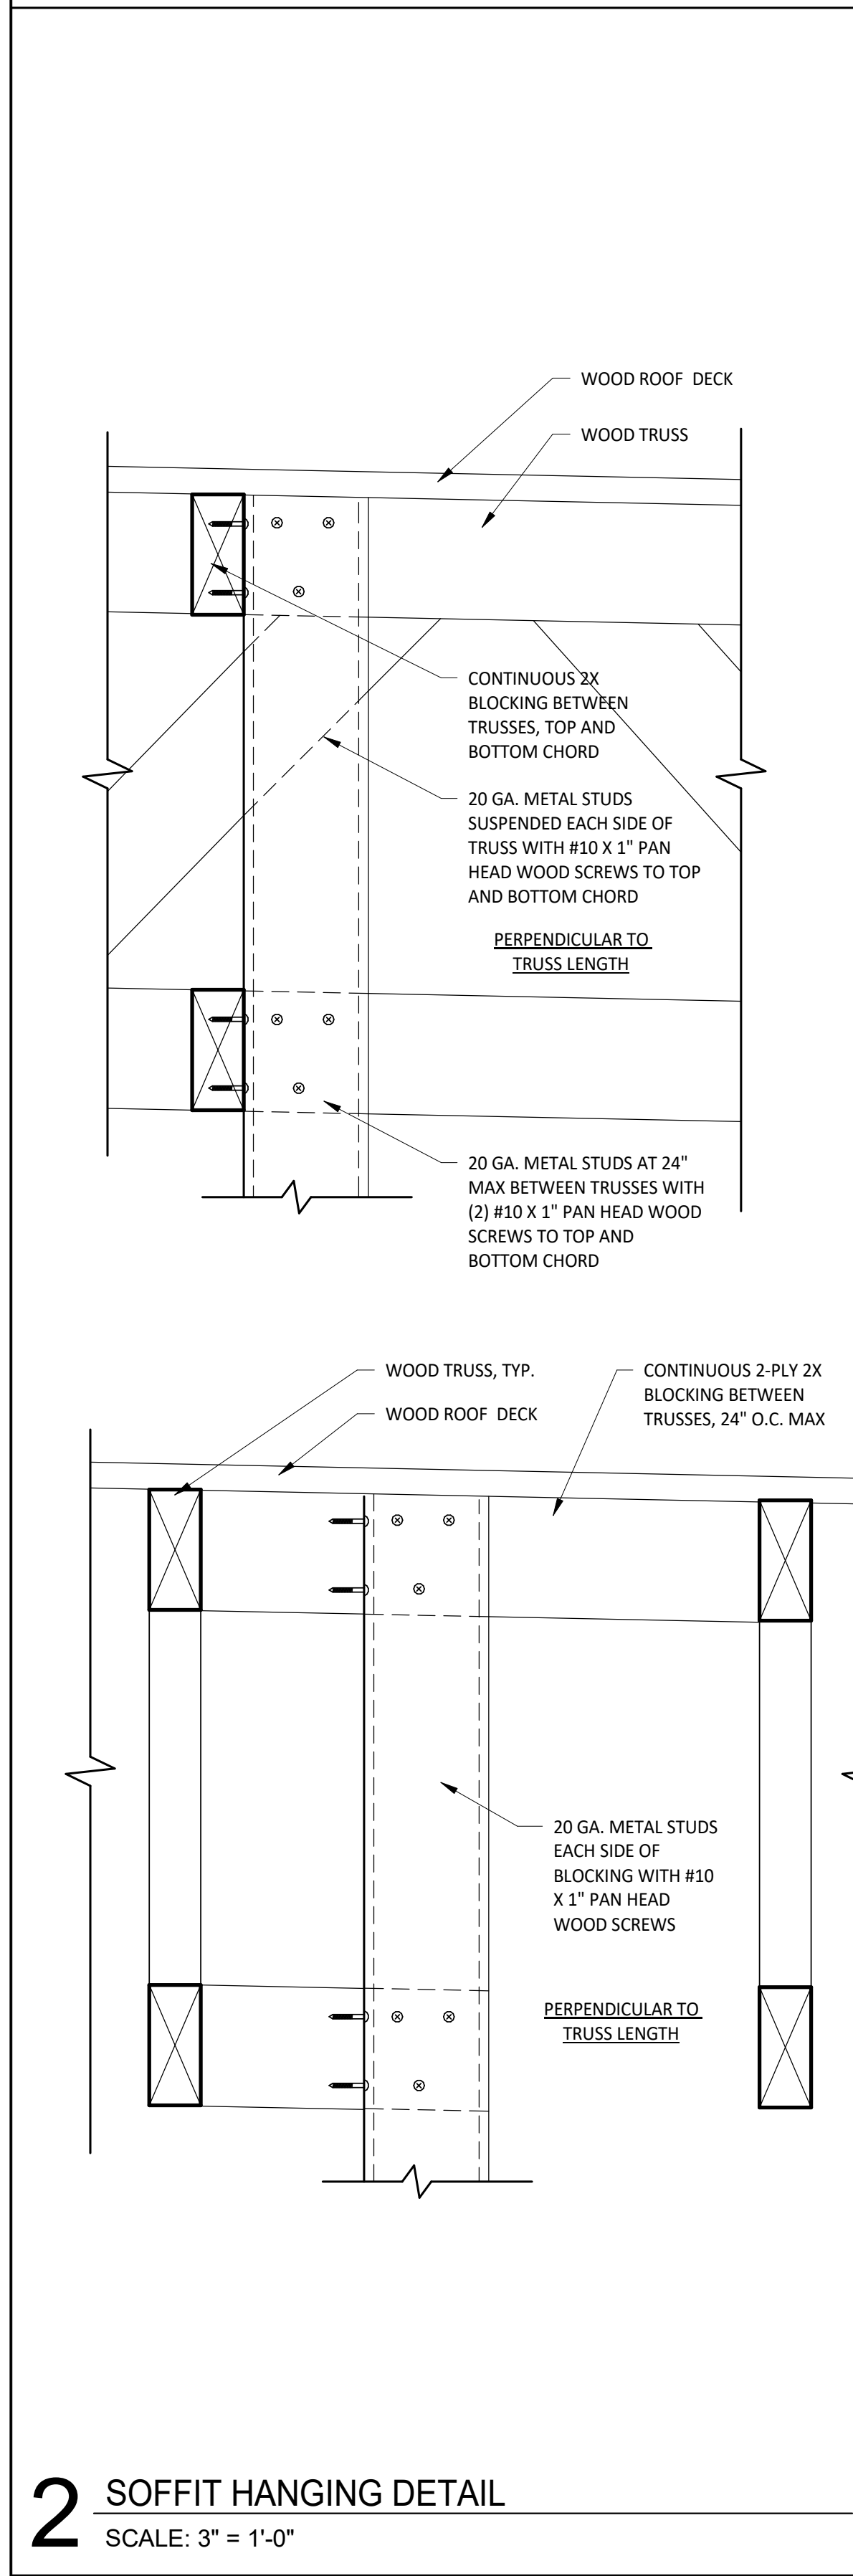


2 SOFFIT HANGING DETAIL
SCALE: 3" = 1'-0"


WALL TYPES

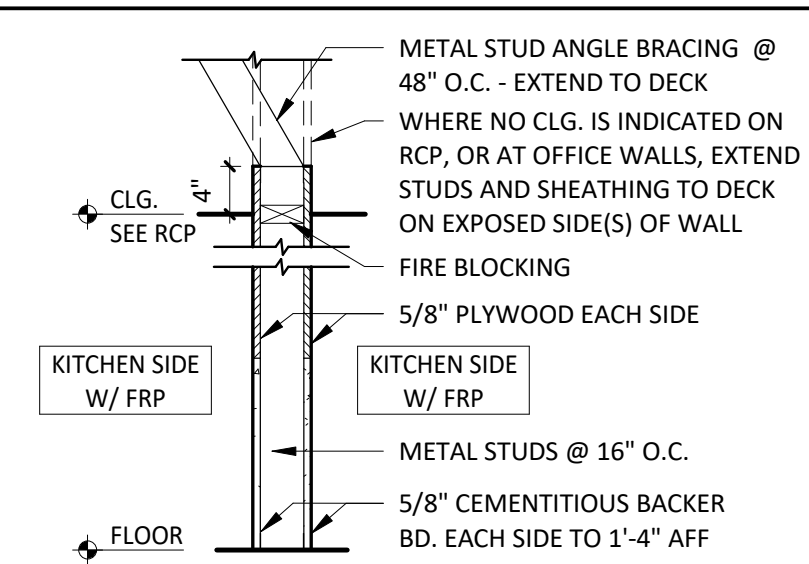


W1 INTERIOR PARTITION
W1a INTERIOR PARTITION (1-SIDE ONLY)

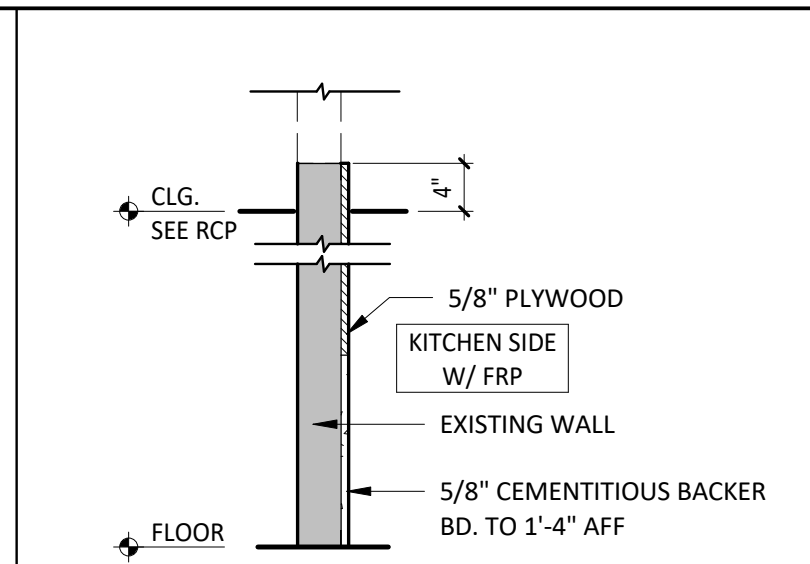


W1ax INTERIOR PARTITION (SUBSTRATE ONLY)

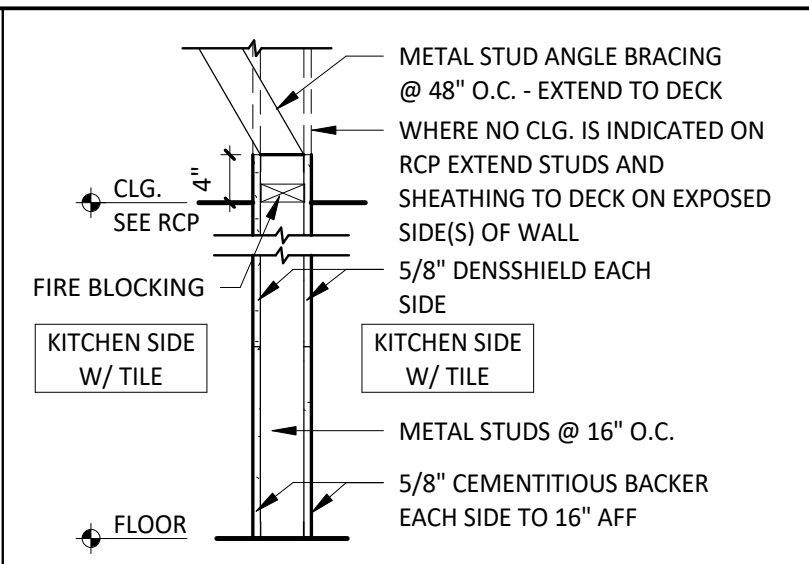


W3 INTERIOR PARTITION
W3a INTERIOR PARTITION (1-SIDE ONLY)

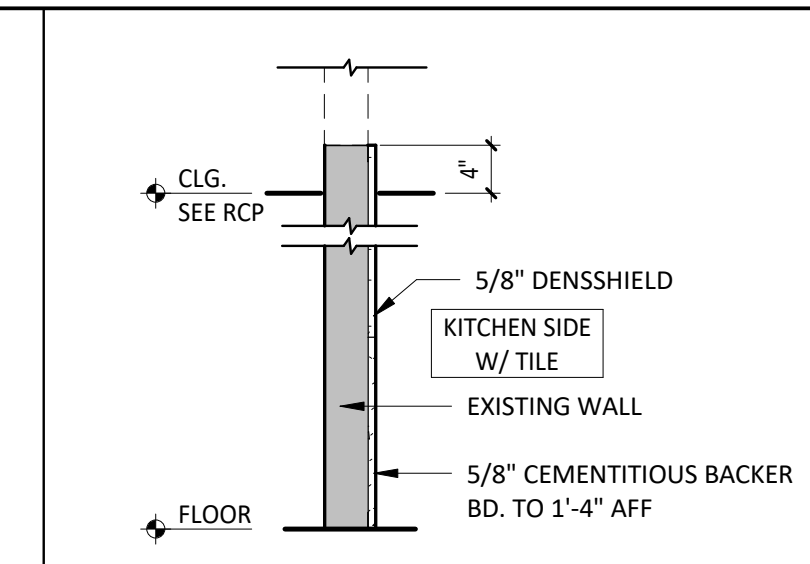


W3ax INTERIOR PARTITION (SUBSTRATE ONLY)

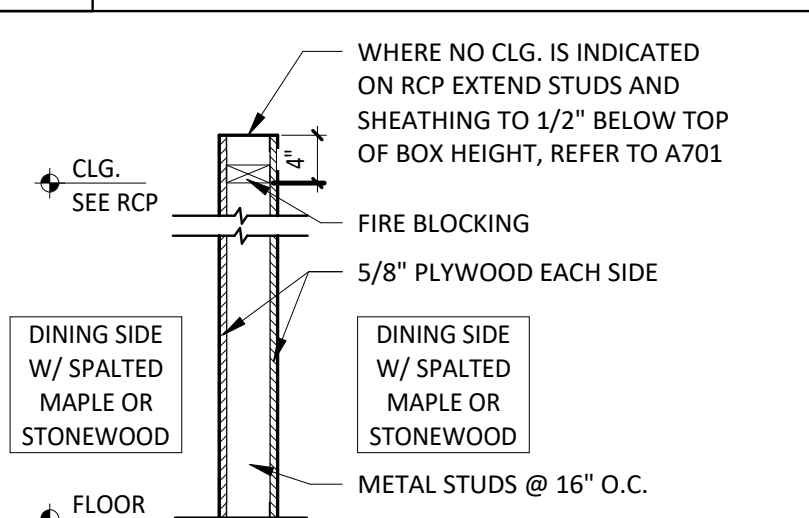


W4 INTERIOR PARTITION
W4a INTERIOR PARTITION (1-SIDE ONLY)

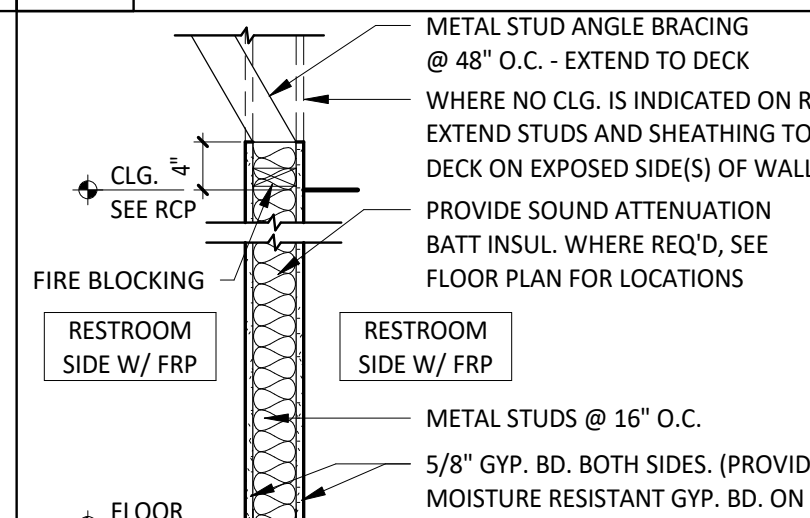


W5 INTERIOR PARTITION
W5a INTERIOR PARTITION (1-SIDE ONLY)

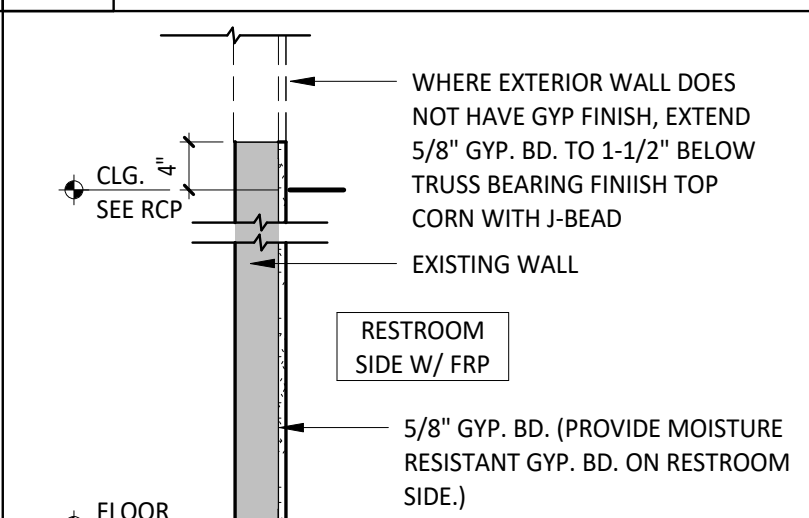


W5ax INTERIOR PARTITION (SUBSTRATE ONLY)

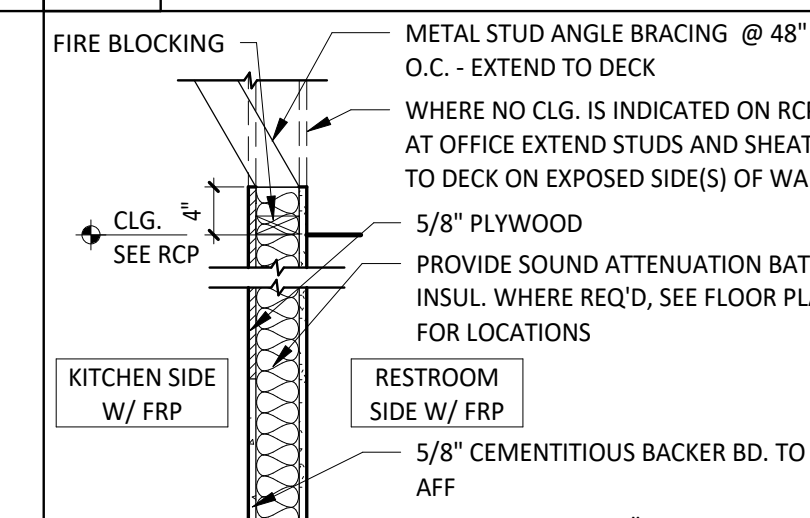


W6 INTERIOR PARTITION

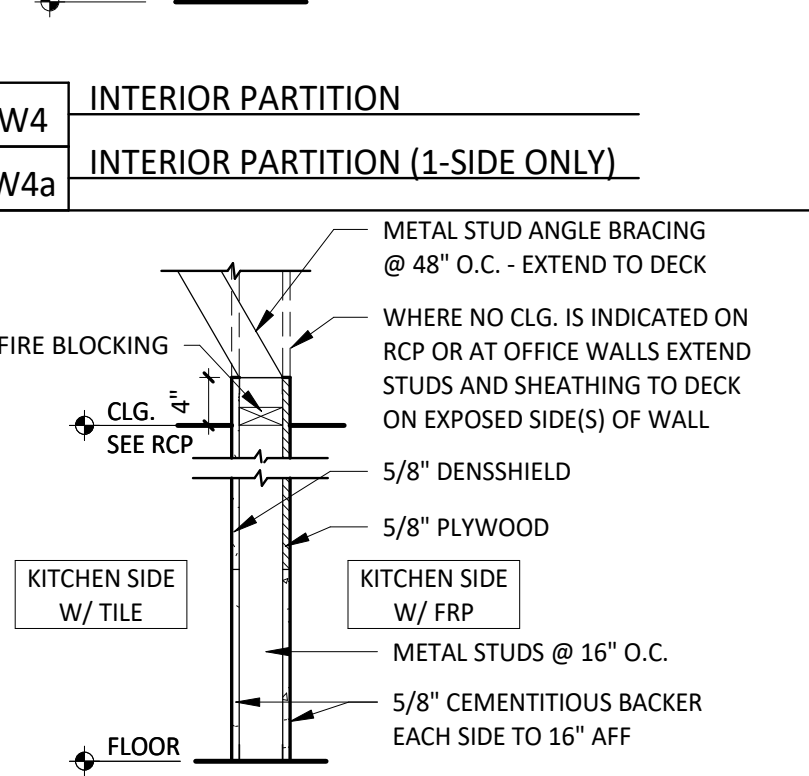


W7 INTERIOR PARTITION

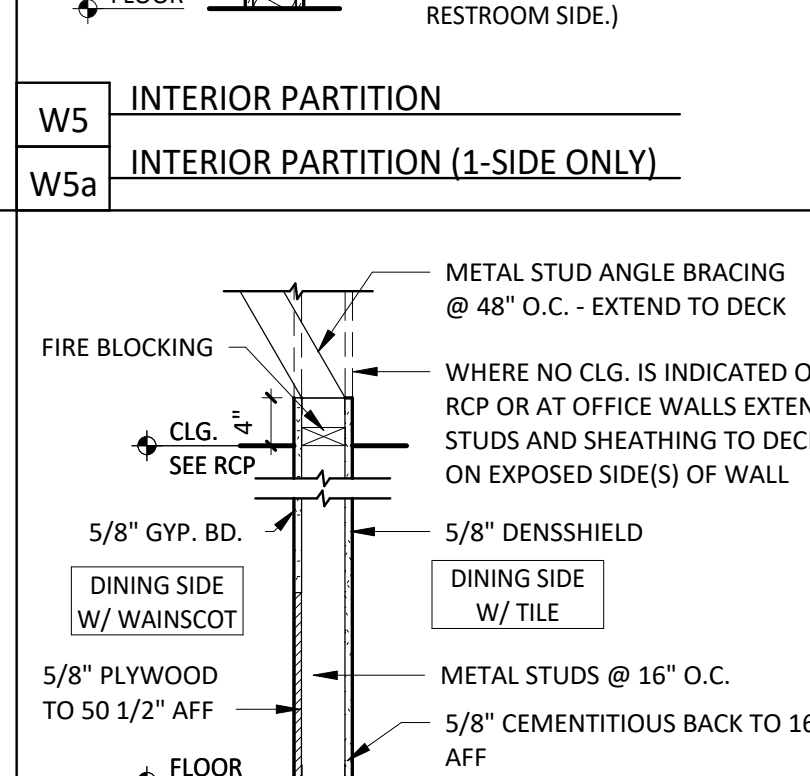


W8 INTERIOR PARTITION

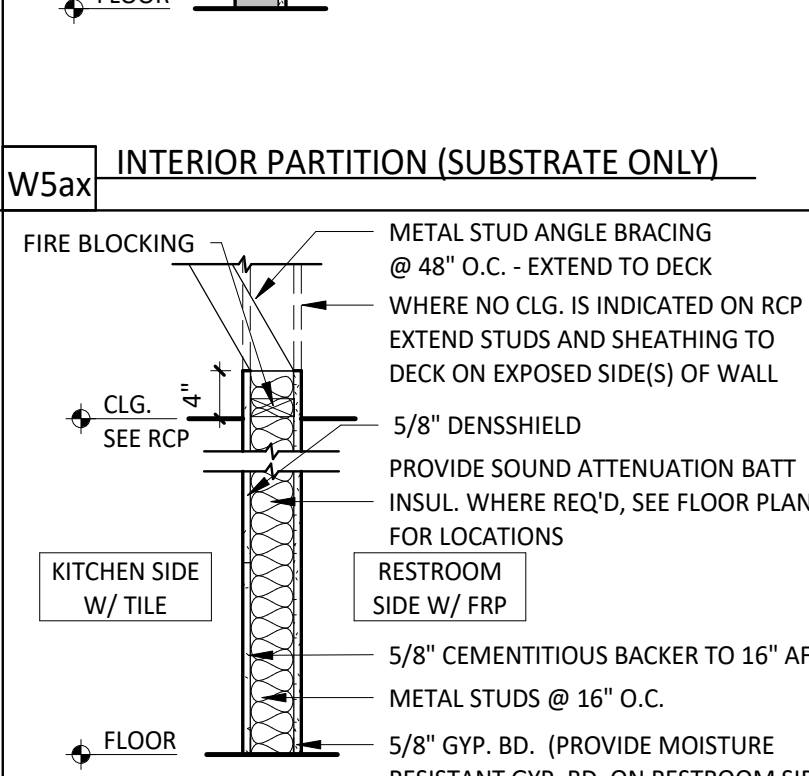


W9 INTERIOR PARTITION

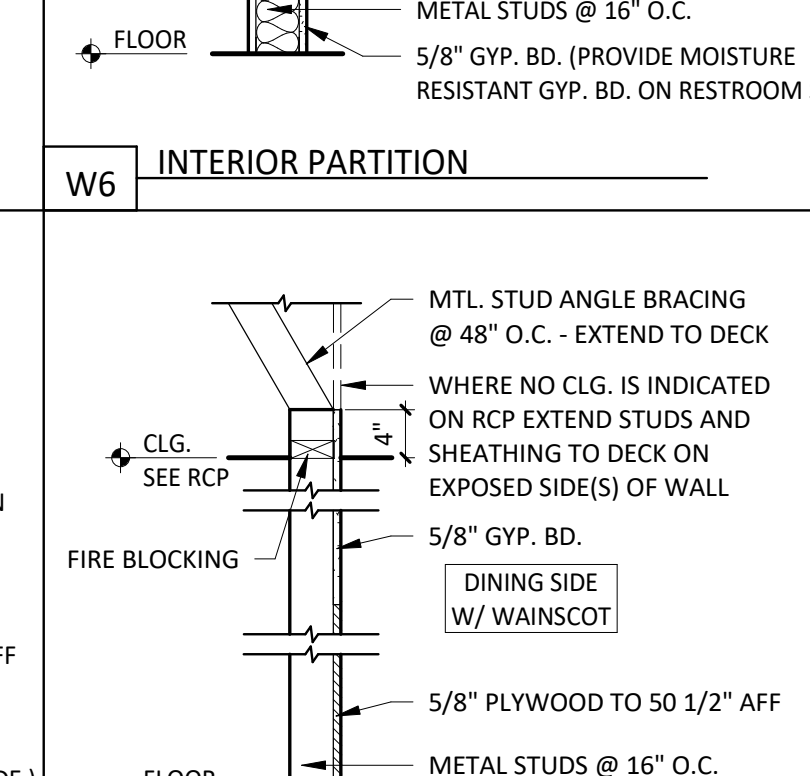


W10a INTERIOR PARTITION

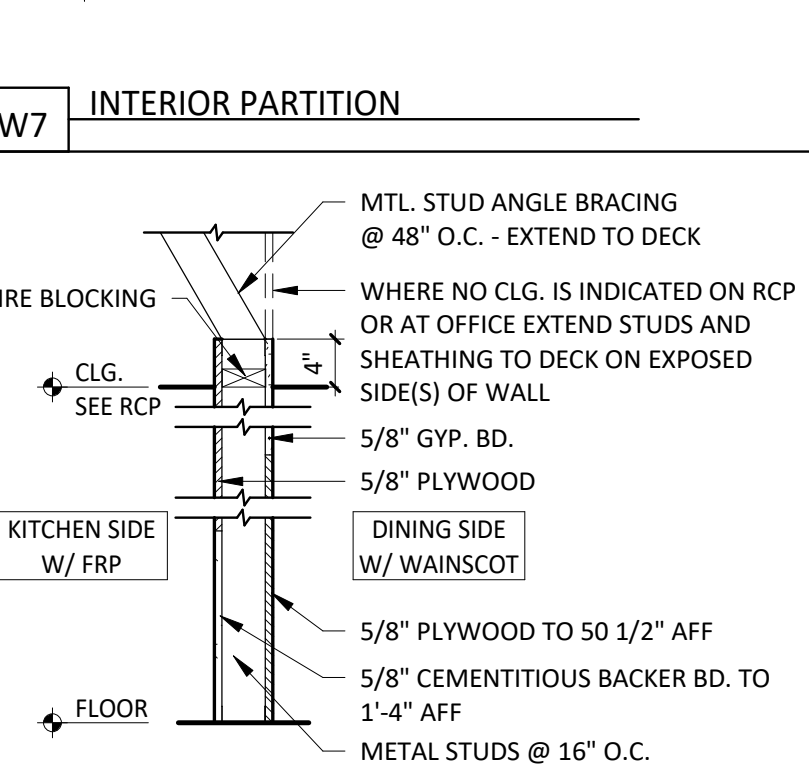


W11 INTERIOR PARTITION

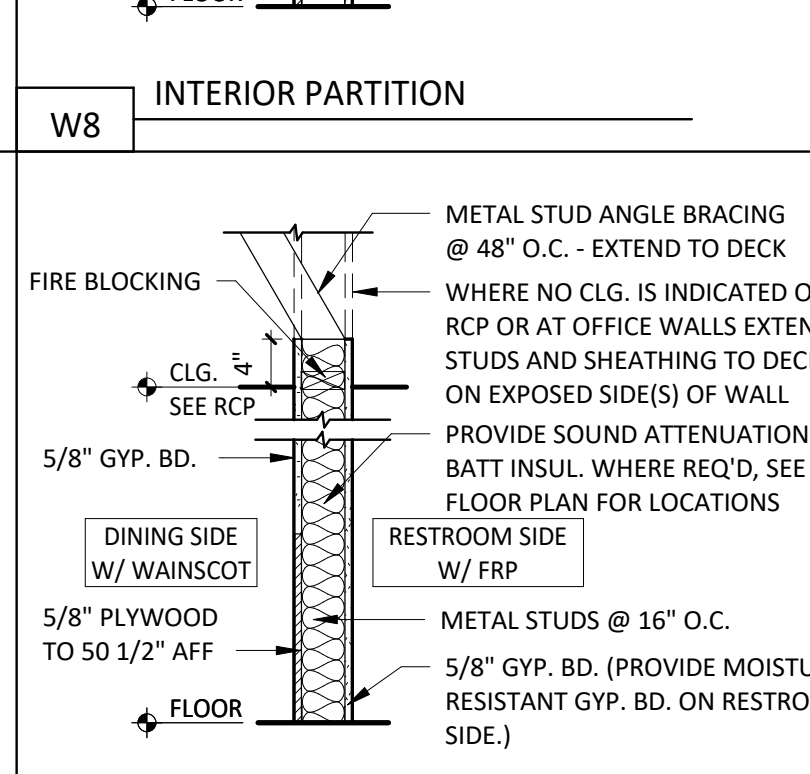


W14 INTERIOR PARTITION

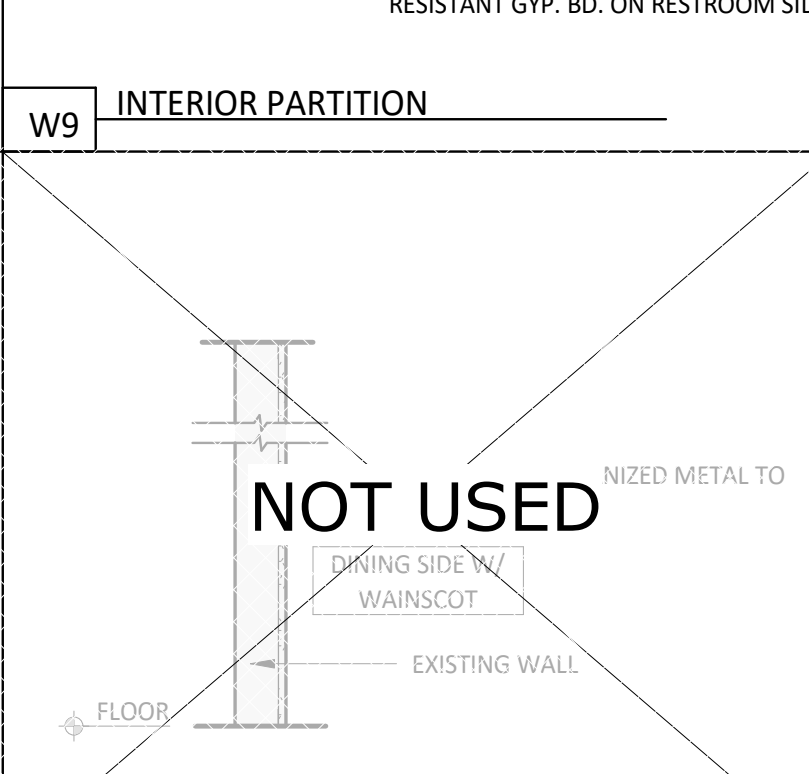


W16ax INTERIOR PARTITION

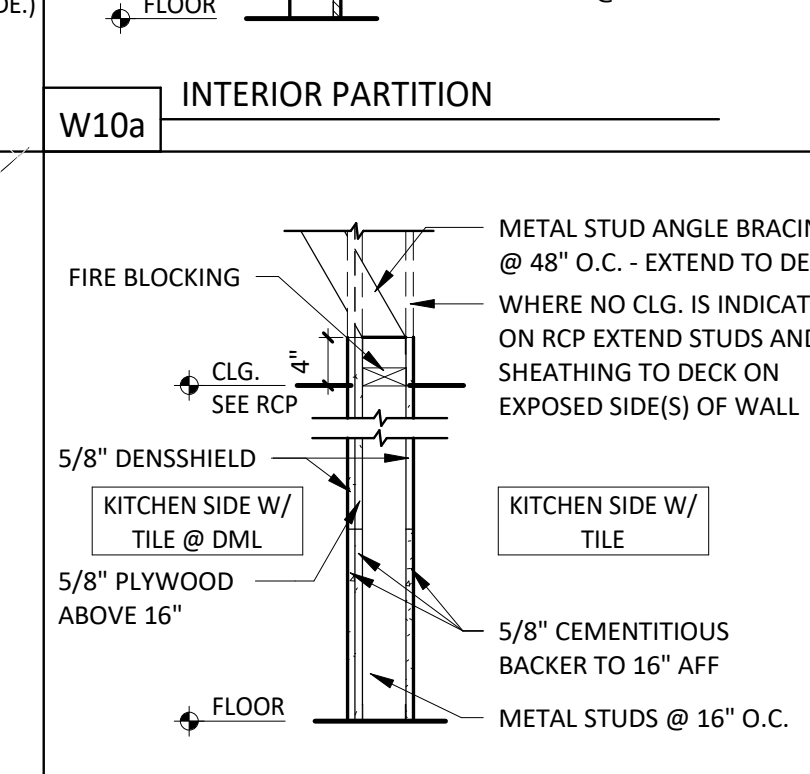


W23 INTERIOR PARTITION

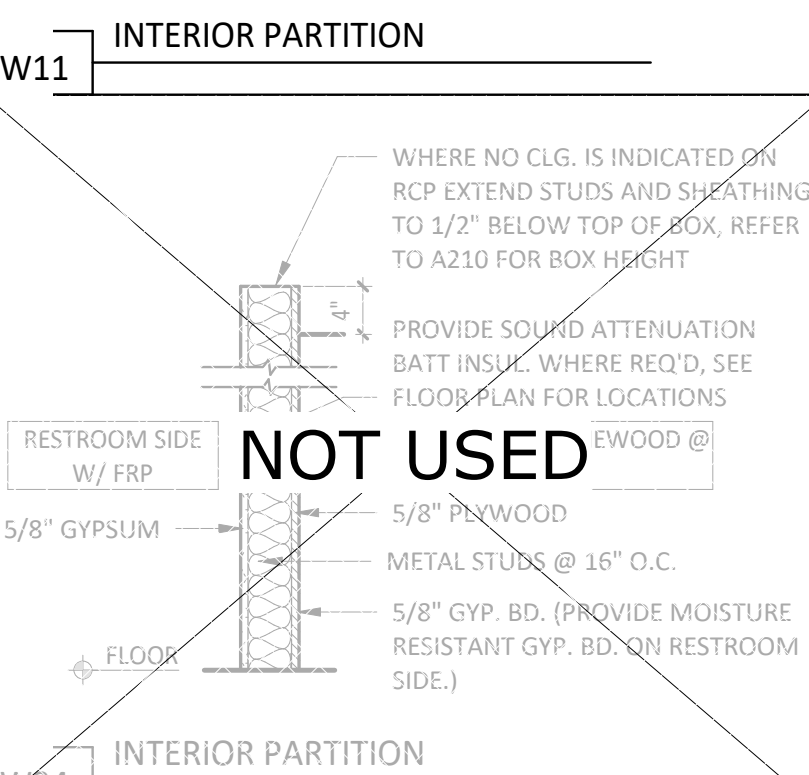


W24 INTERIOR PARTITION

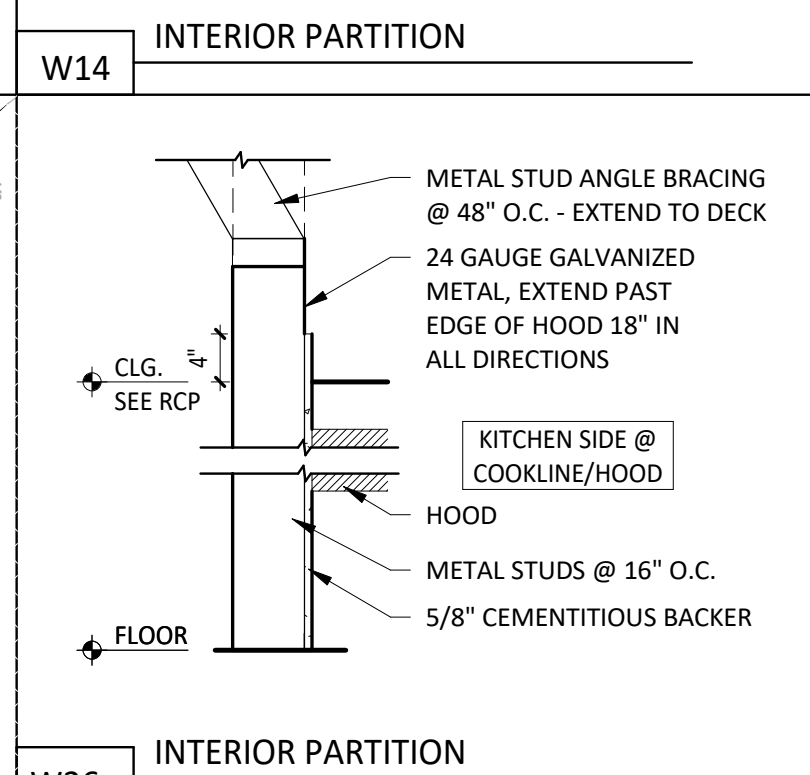


W26a INTERIOR PARTITION

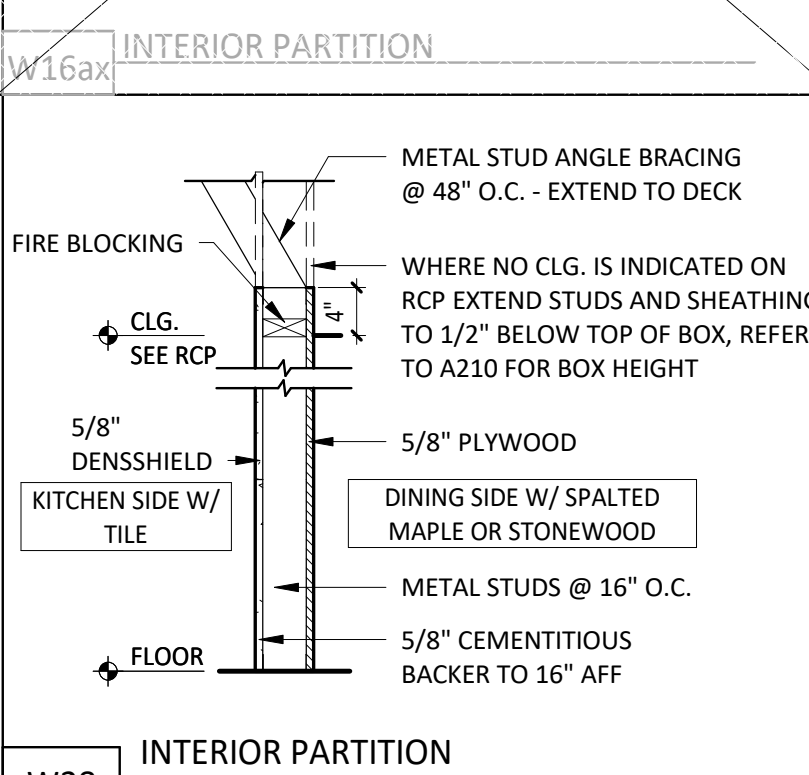


W28 INTERIOR PARTITION

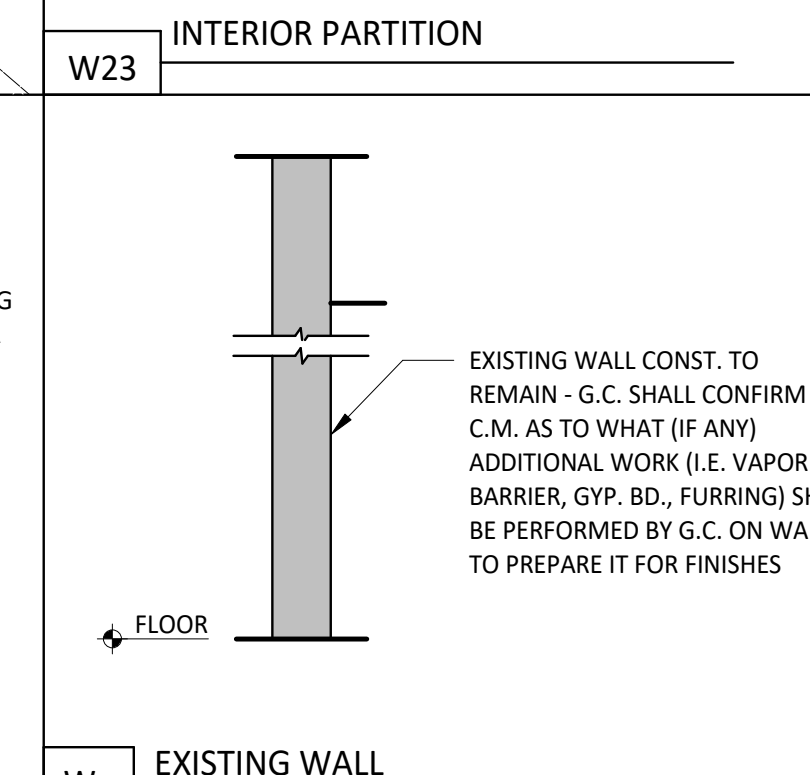

Wx EXISTING WALL

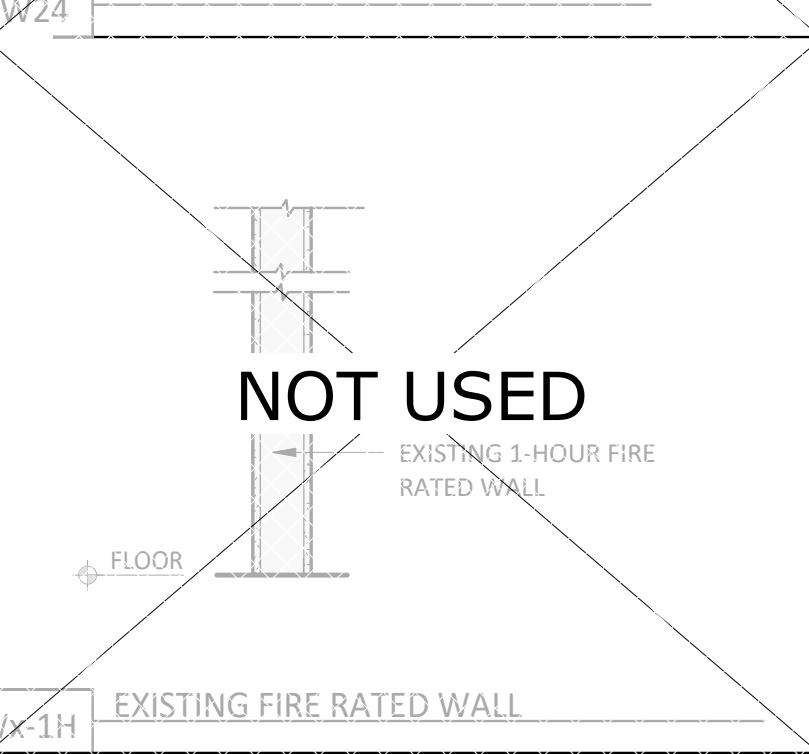

Wx-1H EXISTING FIRE RATED WALL

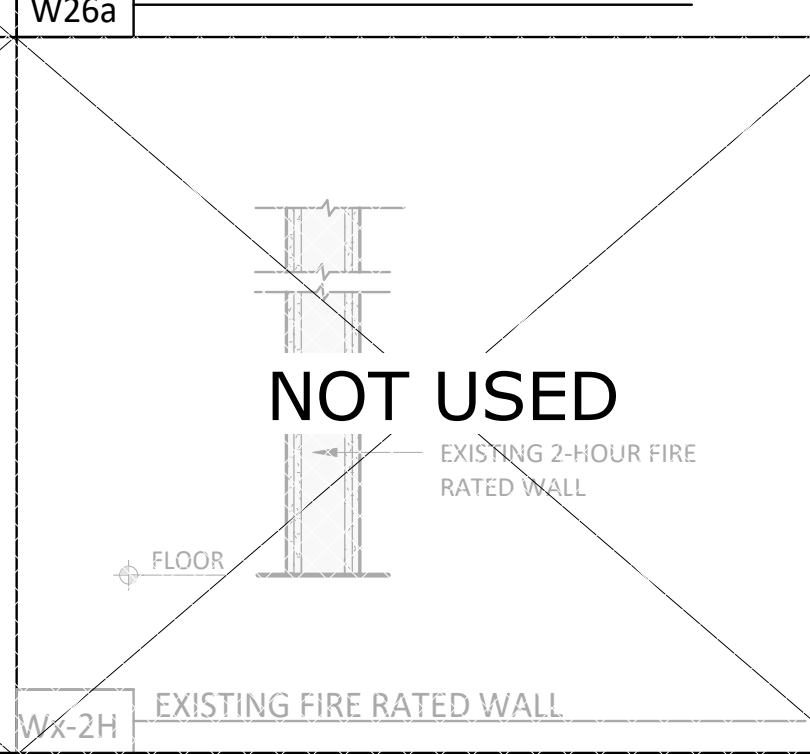

Wx-2H EXISTING FIRE RATED WALL

GENERAL NOTES - WALL TYPES

- REFER TO FINISH SCHEDULE AND CERAMIC TILE WALL FINISHES KEY PLAN ON SHEET A120 FOR WALL FINISHES, REFER TO FLOOR PLAN ON A110 FOR METAL STUD SIZE.
- G.C. SHALL PROVIDE SOLID BLOCKING IN WALLS AS REQUIRED OR AS NEEDED.
- STUDS ARE 3 5/8" METAL STUDS UNLESS OTHERWISE NOTED ON PLAN.


STUD SCHEDULE & NOTES

- ALL HEIGHTS REFER TO UN-BRACED HEIGHTS.
- ALL HEIGHTS BASED ON 16" O.C. SPACING.
- BOTTOM TRACK TO BE SAME GAUGE AS STUD.
- TOP TRACK TO BE ONE GAUGE HIGHER.

SIZE/TYPE	W/O HUNG SHELVING	W/ HUNG SHELVING
362S125-18	UP TO 12'-0"	
362S137-33	UP TO 16'-0"	UP TO 12'-0"
600S137-33	UP TO 22'-0"	UP TO 16'-0"
600S162-43	UP TO 26'-0"	UP TO 22'-0"

PARTITION NOTES

- ALL METAL STUDS TO CONFORM TO LOCAL BUILDING CODES.
- ALL STUD WALLS AND PARTITIONS REQUIRE GYP. BOARD ON BOTH SIDES FOR THE FULL HEIGHT OF THE STUDS UNLESS SPECIFICALLY DETAILED OTHERWISE.
- ALL SUSPENDED WALLS SHALL HAVE GYP. BOARD WHICH EXTENDS 4" ABOVE THE SUSPENDED CEILING UNLESS SHOWN AND/OR NOTED OTHERWISE BY THE ARCHITECT.
- FIRE RETARDANT PLYWOOD MAY SUBSTITUTE FOR GYP. BOARD WHERE SO DIRECTED BY THE ARCHITECT.
- ALL STUD WALLS AND PARTITIONS SHALL HAVE CONTINUOUS LINES OF BRIDGING SPACED AT 4'-0" MAXIMUM ON CENTER. THE BRIDGING SHALL BE SECURELY FASTENED TO THE STUDS WITH EITHER SCREWS OR WELDS. REFER TO DETAILS THIS SHEET.
- ALL STUDS SHALL BE "CEE" STUDS WITH FLANGE STIFFENERS.
- THE MATERIALS AND DETAILS SHOWN ARE FOR TYPICAL INSTALLATIONS. WHERE THE STUD MANUFACTURER'S RECOMMENDATIONS OR LOCAL ORDINANCES ARE MORE RESTRICTIVE, THEY SHALL APPLY.
- TYPICAL FASTENER:
 - STEEL STUDS TO STEEL STUDS OR TRACKS:
20 GAUGE - #8 - 18 X 1 1/2" TEKS WITH PHILIPS PAN HEAD - MIN. 2 PER CONNECTION
18/16 GAUGE - #10 - 16 X 3/4" TEKS WITH PHILIPS PAN HEAD - MIN. 3 PER CONNECTION
 - STEEL STUDS OR TRACKS TO WOOD PURLINS, GIRDERS AND BEAMS:
#14 - 10 X 1 1/2" H.W.H. TYPE "S" METAL-TO-WOOD TEKS AT 12" O.C., 2" FROM EACH END
 - STEEL STUDS OR TRACKS TO STRUCTURAL STEEL (TUBE/WIDE FLANGE COL'S, BM'S, GIRDER'S, ETC.)
0.145" DIA. HILTI X-EDNI FASTENERS, 5/8" MIN. LENGTH AND MIN. OF 2 PER CONNECTION, OR 2 ROWS AT 16" O.C. FOR CONTINUOUS APPLICATIONS SUCH AS TRACKS, U.N.O.
 - PLYWOOD TO STEEL STUDS:
#10 - 24 X 1 1/4" TEKS/3 (PLYMETALTEKS) WITH THIN WAFER HEAD - 24" O.C. FILED, 12" O.C. PERIMETER
 - GYPSUM BOARD TO STEEL STUDS:
#7 X 1-1/4" HI-LOW TYPE "S" BUGLE HEAD SCREWS FOR 3/8" TO 5/8" GYPSUM BOARD TO 25 GAUGE OR 20 GAUGE STUDS
#6 X 1-1/4" TYPE S-12 BUGLE HEAD SCREWS FOR 3/8" TO 5/8" TO 18 GAUGE OR 16 GAUGE STUDS OR TRACKS
FIELD - 12" O.C. CEILINGS, 24" O.C. WALLS
BUTT JOINTS 12" O.C.
 - STEEL STUDS OR TRACKS TO CONCRETE:
0.145" DIA. HILTI X-DNI FASTENER, 1" MIN. LENGTH, 2 ROWS AT 16" O.C.

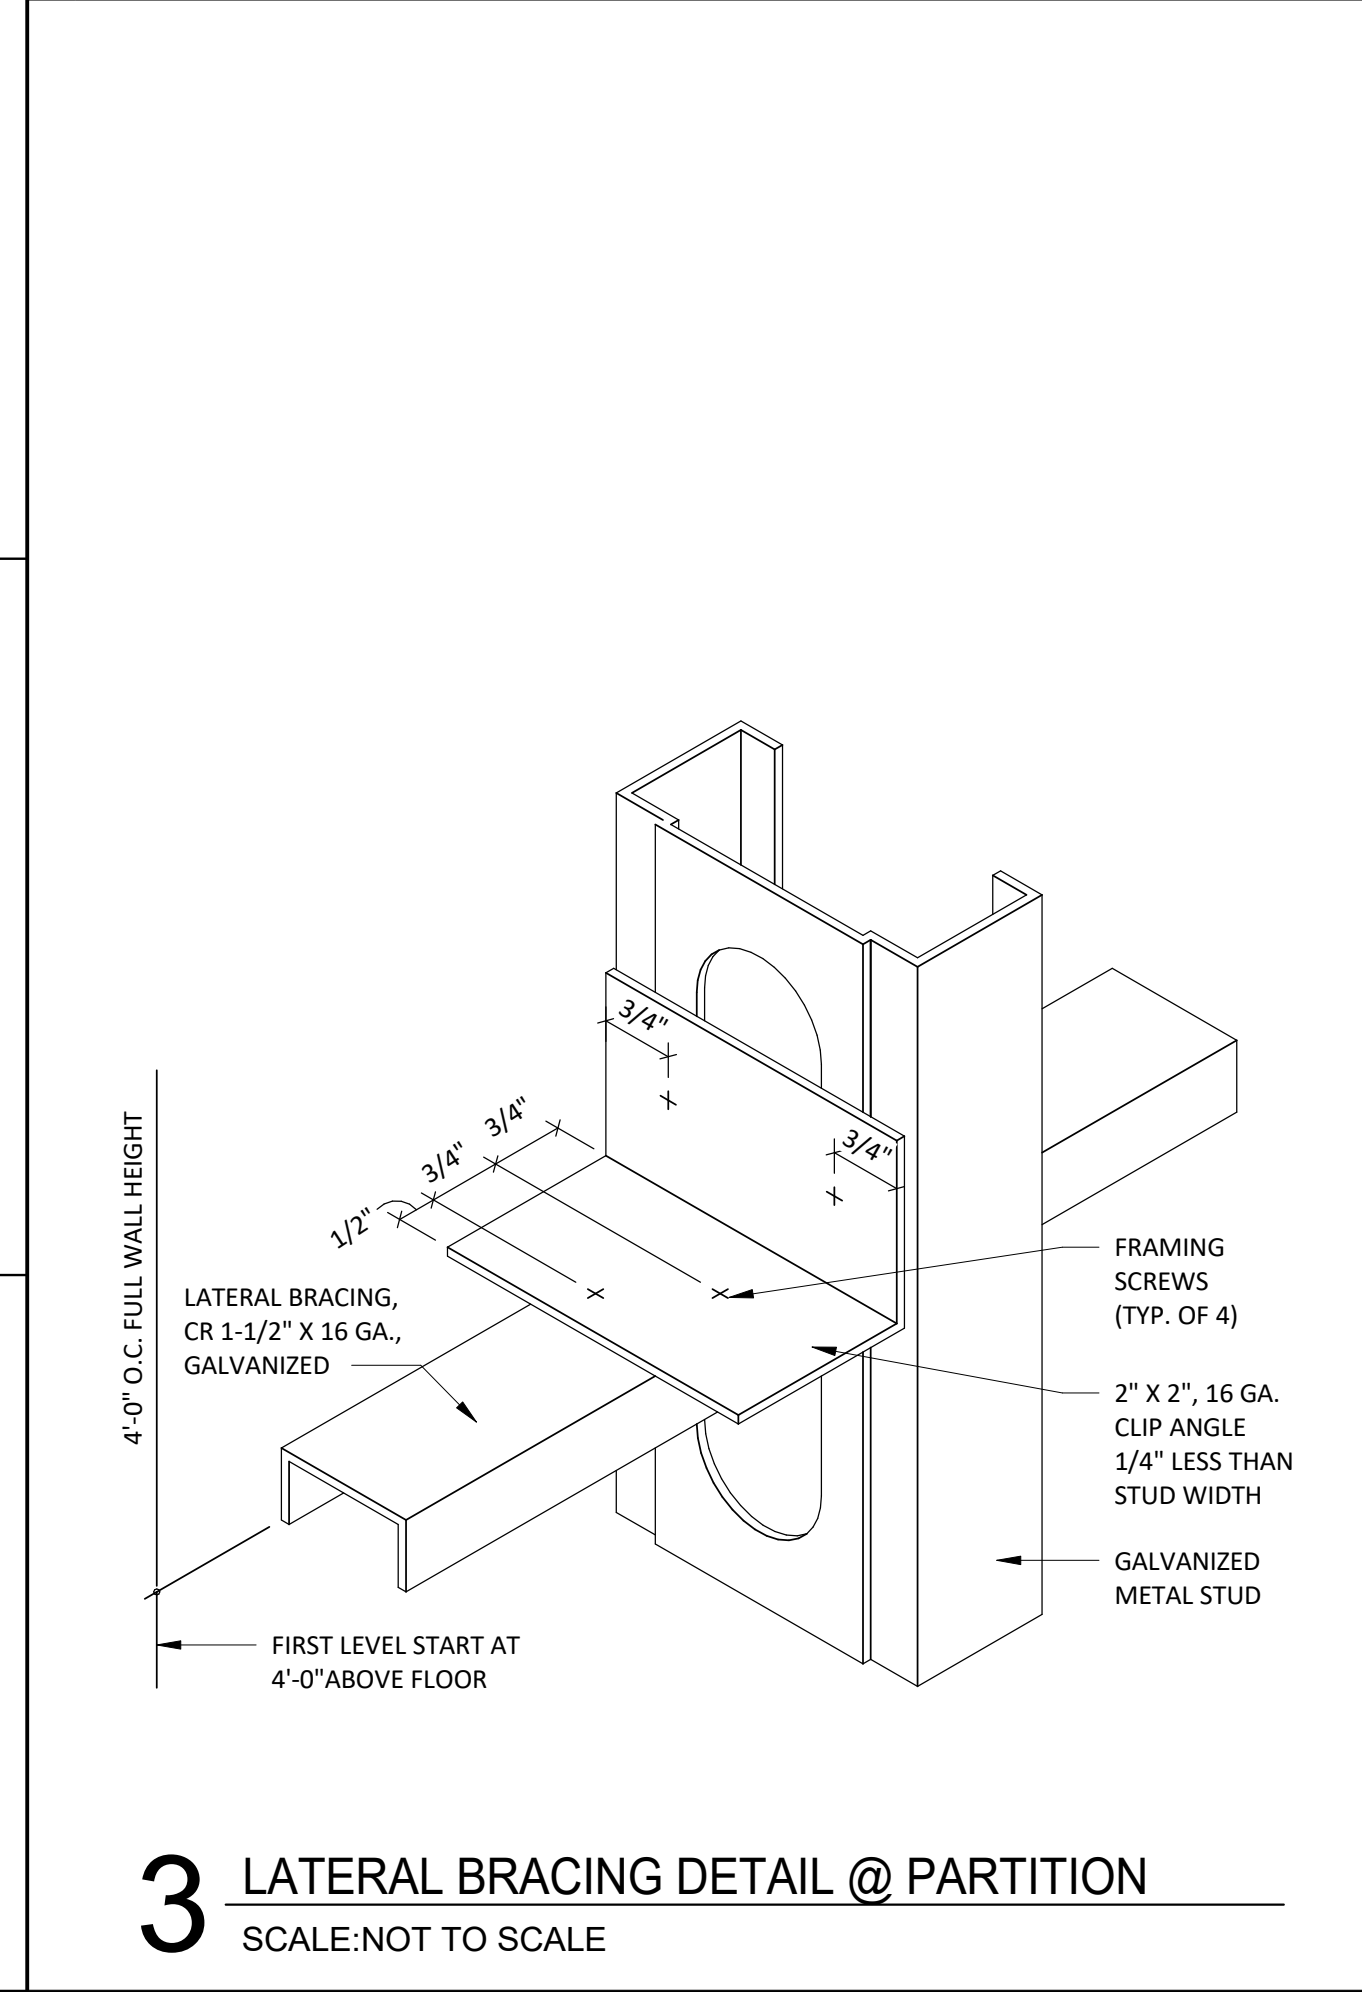

3 LATERAL BRACING DETAIL @ PARTITION
SCALE: NOT TO SCALE

CONSULTANT:



CLIENT:



CHIPOTLE MEXICAN GRILL, INC.
PO BOX 10566
COLUMBUS, OH 43210-2666
TELEPHONE: (614) 318-2482
INTERNET: WWW.CHIPOTLE.COM


COPYRIGHT 2024
THIS DRAWING IS AN INSTRUMENT OF SERVICE AND AS SUCH REMAINS THE PROPERTY OF CHIPOTLE MEXICAN GRILL, INC. PERMISSION FOR USE OF THIS DOCUMENT IS LIMITED AND CAN BE EXTENDED ONLY BY WRITTEN AGREEMENT WITH CHIPOTLE MEXICAN GRILL, INC.

PROJECT INFORMATION:

STORE NO.: 5037

HUNTLEY
12990 ROUTE 47, LOT 4B
HUNTLEY, IL 60142

SEAL:

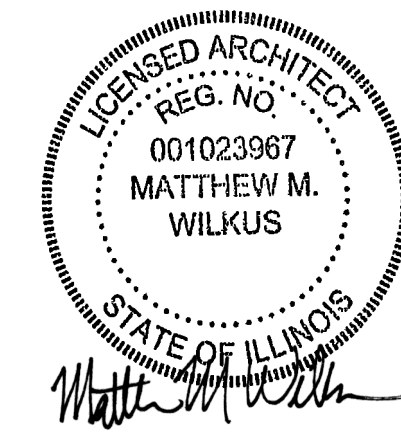

MATTHEW M. WILKUS
LICENSE #001.023967
(EXPIRES 11/30/2024)

PROJECT NO. 2023-0175
DRAWN BY JSB, DVA
CHECKED BY DVA, NSG, KAM, MMW


ISSUE RECORD:
02/12/2024 PERMIT SUBMITTAL
03/15/2024 BID SET
05/03/2024 CONSTRUCTION SET

REVISIONS:

TITLE:
ARCHITECTURAL
WALL TYPES

SHEET NUMBER:


A111

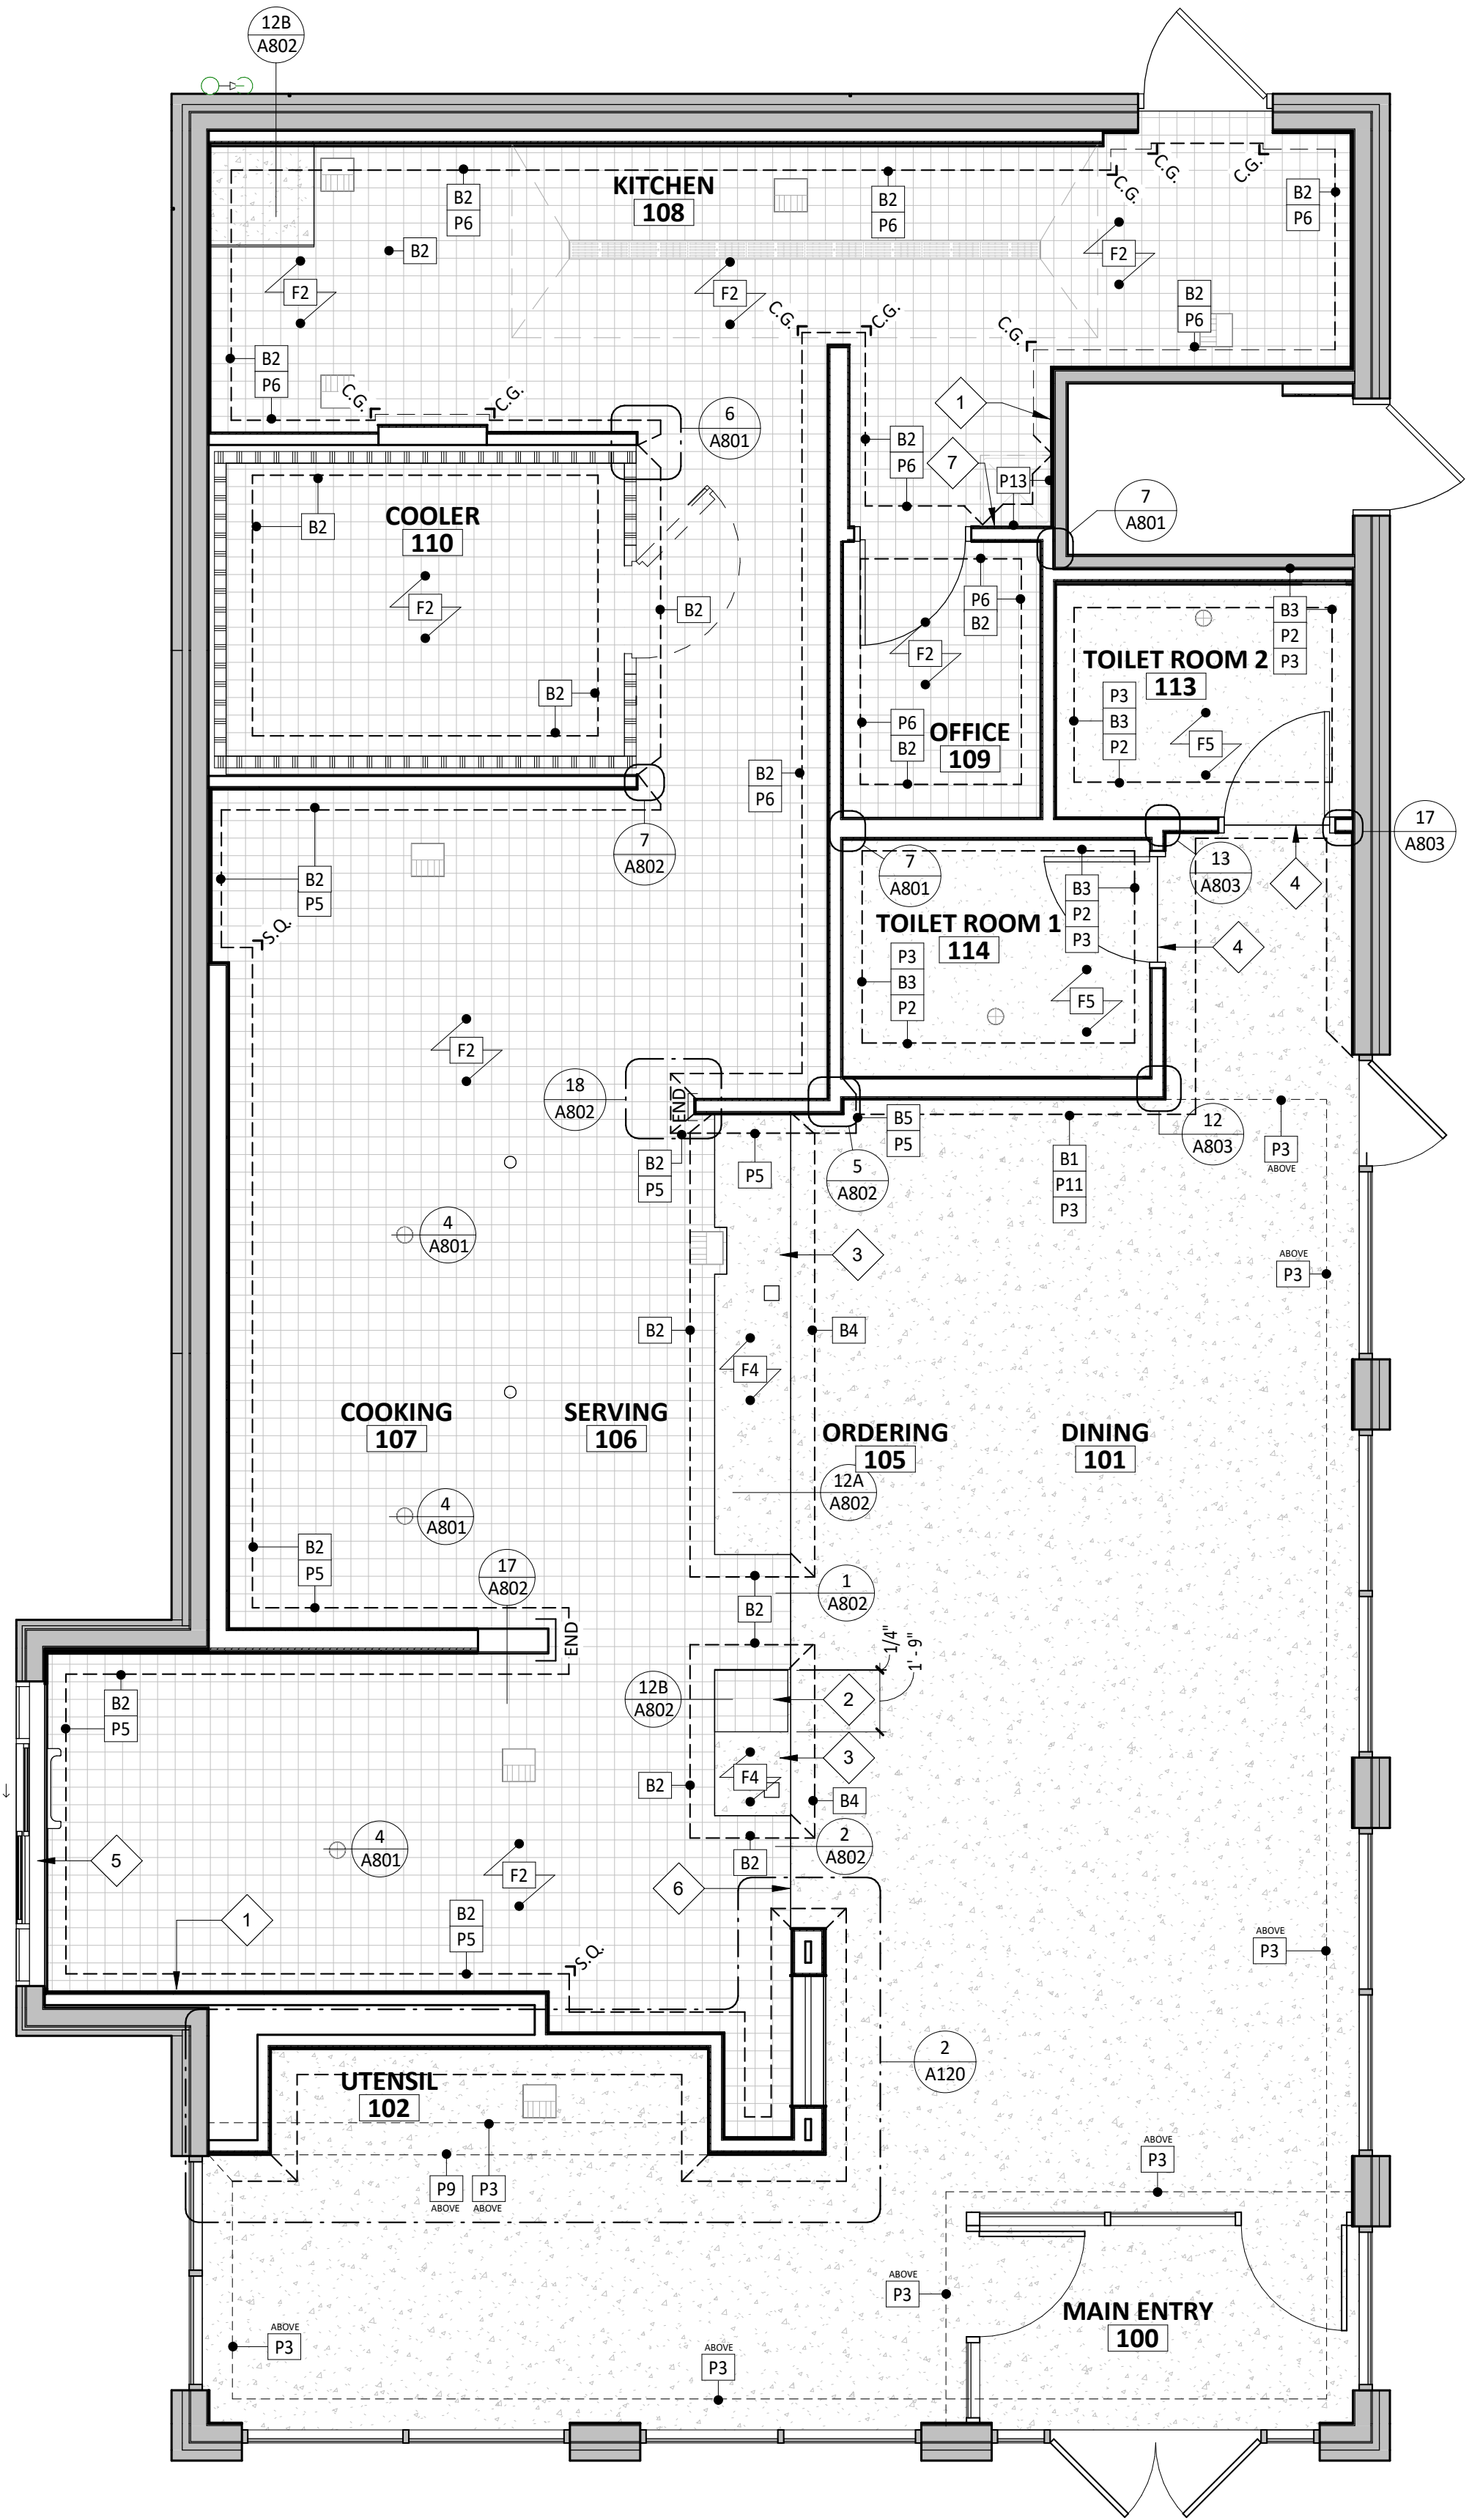

1 FINISH PLAN
SCALE: 1/4" = 1'-0"

FINISH LEGEND

LGD. #	FLOOR FINISHES	LGD. #	WALL BASE FINISHES	LGD. #	CEILING/DECK FINISHES
F1	POLISHED CONCRETE	B1	BLACK RUBBER, COVELESS	C1	OPEN TO STRUCTURE, UNPAINTED
F2	QUARRY TILE	B2	QUARRY TILE, COVE	C2	STONEWOOD
F3	EXISTING EXTERIOR CONCRETE	B3	BLACK RUBBER, COVE	C3	GYP BD; PAINT "MOONLIT SNOW"
F4	SEALED CONCRETE	B4	QUARRY TILE, COVELESS	C4	2X4 VINYL-FACED LAY-IN
F5	RESINOUS FLOORING	B5	CERAMIC TILE	C5	FELT BAFFLES
F6	PORCELAIN TILE				
LGD. #	DOOR FINISHES	LGD. #	WALL BASE FINISHES		
D1	PAINT "BLACK"	P1	GYP BD; PAINT "MOONLIT SNOW"		
D2	PAINT "KNIGHTS ARMOR"	P2	FIBERGLASS REINFORCED PANELS TO 4'-0" AFF (SMOOTH)		
		P3	GYP BD; PAINT "THIN ICE", EGGSHELL, REFER TO A701 AND A710		
		P4	GYP BD; PAINT "THIN ICE", SEMI-GLOSS BELOW 4'-3" AFF		
		P5	CERAMIC TILE - WHITE		
		P6	FIBERGLASS REINFORCED PANELS (PEBBLED FINISH)		
		P7	NOT USED		
		P8	CERAMIC TILE - BRONZE ACCENT 3" X 12"		
		P9	SPALTED MAPLE WALL PANEL, HORIZONTAL GRAIN		
		P10	EXISTING STOREFRONT		
		P11	STONEWOOD WALL PANEL		
		P12	EXISTING PREFINISHED BRAKE METAL		
		P13	STAINLESS STEEL		

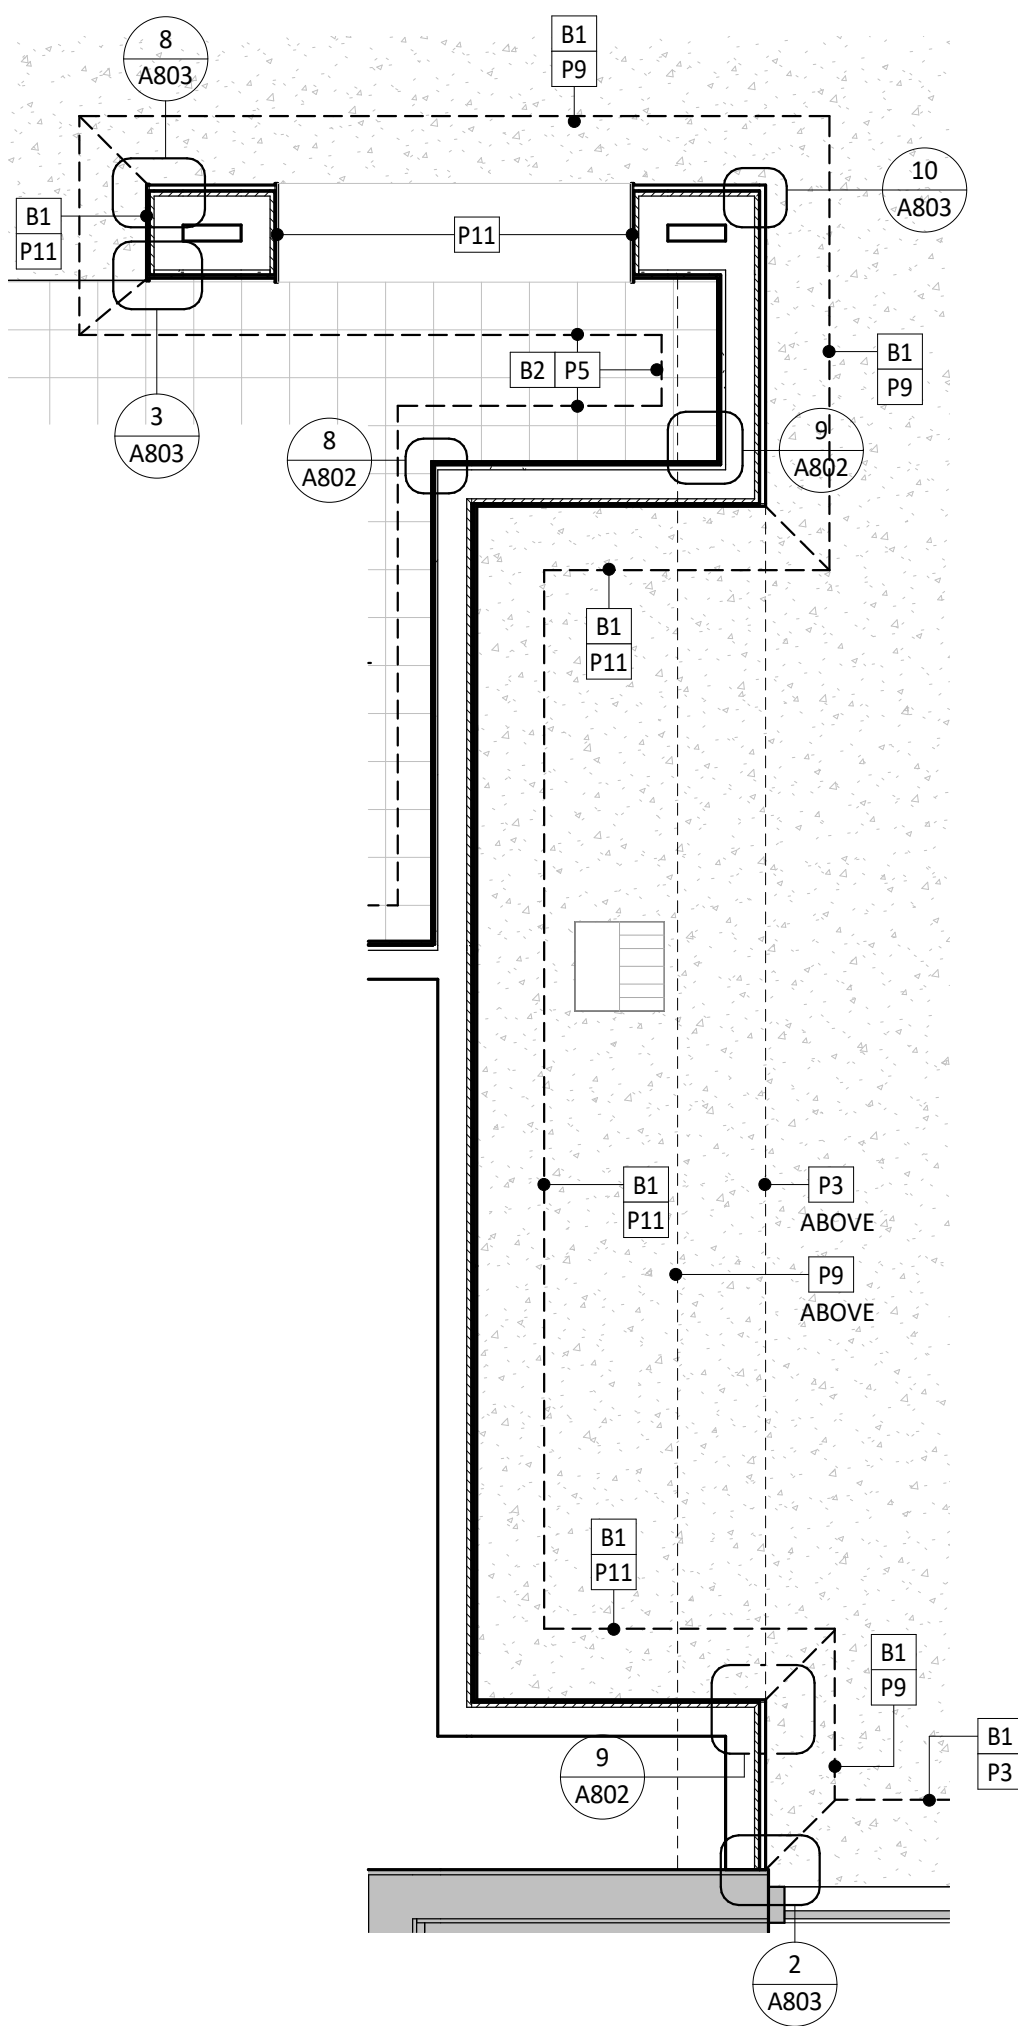

2 ENLARGED FINISH PLAN
SCALE: 1/2" = 1'-0"

GENERAL NOTES - FINISH PLAN

- A. STONEWOOD WALL PANELS AND WAINSCOTS PROVIDED BY TMS, INSTALLED BY GC.
B. SPALTED MAPLE PANELS PROVIDED BY TMS, INSTALLED BY GC.
C. GC IS RESPONSIBLE FOR SEQUENCING OF PREWIRING WITH COMPLETION OF INTERIOR FINISHES (GYP. BD. FINISHES).
D. PROVIDE WATER PROOFING MEMBRANE, REFER TO A802 DETAILS. PROVIDE ON INTERIOR OF ALL RESTROOM WALLS, REFER TO A801 DETAILS
E. GC SHALL PROVIDE STAINLESS STEEL BASE AT ALL OUTSIDE QUARRY TILE CORNERS IN KITCHEN ONLY - REFER TO SPECIFICATIONS AND A802 FOR DETAILS.

FINISH PLAN SYMBOL LEGEND

- = PROVIDE A SCHLUTER QUADEC METAL CORNER AT ALL TILED CORNERS - REFER TO A802 FOR ADDITIONAL INFORMATION
 = PROVIDE 1 1/2" X 1 1/2" STAINLESS STEEL CORNER GUARD UP TO 5'-0" A.F.F. - 1 1/2" X 1 1/2" FRP CORNER GUARD FROM TOP TO CEILING- REFER TO A802 FOR ADDITIONAL INFORMATION
 = PROVIDE END GUARD - REFER TO A802 FOR ADDITIONAL INFORMATION

KEYNOTE LEGEND

- 1 GENERAL CONTRACTOR TO PROVIDE 18 GAUGE STAINLESS STEEL SHROUD AROUND EXPOSED LINES AT ICE MAKER.
2 PROVIDE QUARRY TILE ON TOP OF CURB FOR SMART SAFE - PROVIDE BULLNOSE TILE TO LAP OVER TOP CUT EDGE OF BASE TILE - REFER TO A802 FOR ADDITIONAL INFORMATION - GENERAL CONTRACTOR TO COORDINATE EXTENT OF QUARRY TILE WITH KES PRIOR TO INSTALLATION.
3 CONCRETE CURB FOR EQUIPMENT WITH QUARRY TILE BASE AT ALL EXPOSED EDGES.
4 EXTENT OF RESINOUS FLOOR FROM RESTROOMS - ALIGN EDGE OF FLOOR WITH CENTER OF DOOR JAMB.
5 ALUMINUM PLATE AT HEAD/JAMB/SILL OF DRIVE-THRU WINDOW - REFER TO A802 FOR ADDITIONAL INFORMATION.
6 EXTENT OF QUARRY TILE FROM KITCHEN.
7 PROVIDE STAINLESS STEEL ON WALL TO 24" ABOVE TOP OF MOP SINK - FLASH BOTTOM EDGE OVER MOP SINK RIM - BEND STAINLESS STEEL AT INSIDE CORNER SO THERE IS NO JOINT - REFER TO A801 FOR ADDITIONAL INFORMATION.

CONSULTANT:



CLIENT:




CHIPOTLE MEXICAN GRILL, INC.
P.O. BOX 162666
COLUMBUS, OH 43216-2666
TELEPHONE: (614) 318-2482
INTERNET: WWW.CHIPOTLE.COM

COPYRIGHT 2024
THIS DRAWING IS AN INSTRUMENT OF SERVICE AND AS SUCH REMAINS THE PROPERTY OF CHIPOTLE MEXICAN GRILL, INC. PERMISSION FOR USE OF THIS DOCUMENT IS LIMITED AND CAN BE EXTENDED ONLY BY WRITTEN AGREEMENT WITH CHIPOTLE MEXICAN GRILL, INC.

PROJECT INFORMATION:

STORE NO.: 5037
HUNTLEY
12990 ROUTE 47, LOT 4B
HUNTLEY, IL 60142

SEAL:

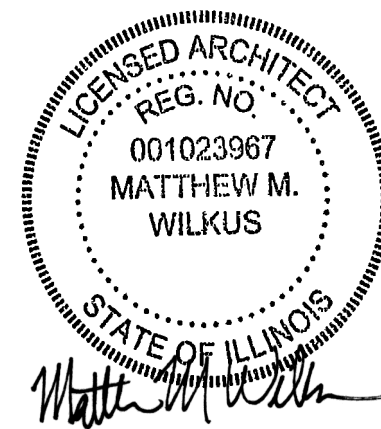

May 06, 2024

MATTHEW M. WILKUS
LICENSE #001.023967
(EXPIRES 11/30/2024)

PROJECT NO. 2023-0175
DRAWN BY JSB, DVA
CHECKED BY DVA, NSG, KAM, MMW

ISSUE RECORD:
02/12/2024 PERMIT SUBMITTAL
03/15/2024 BID SET
05/03/2024 CONSTRUCTION SET

REVISIONS:

TITLE:

FINISH PLAN

SHEET NUMBER:

A120

GENERAL NOTES - FF& E

- A. REFER TO SHEET A131 FOR EQUIPMENT LIST AND FURNITURE SCHEDULE.
B. ALL DIMENSIONS TO EXTERIOR OR EXISTING WALLS ARE TO THE FINISH FACE OF THE EXISTING GYP. BD.
C. ALL DIMENSIONS ARE TO FACE OF FRAMING, EDGE OF EQUIPMENT, OR CENTERLINE OF EQUIPMENT UNLESS NOTED OTHERWISE.
D. ALL FURNITURE TO BE SQUARE/PARALLEL TO TENANT SPACE/WALLS AS SHOWN ON PLANS.


KEYNOTE LEGEND

- 1 CO2 REMOTE FILLER - VERIFY FINAL LOCATION WITH CHIPOTLE'S CONSTRUCTION MANAGER.
2 BYPASS DISTRIBUTION PANEL - SEE ELECTRICAL PLANS FOR ADDITIONAL INFORMATION.
3 HOSE BIBB - REFER TO PLUMBING PLANS FOR ADDITIONAL INFORMATION.
4 CHEMICAL CLEANING DISPENSING SYSTEM WITH INTEGRAL AIR GAP - REFER TO PLUMBING PLANS FOR ADDITIONAL INFORMATION.
5 WATER FILTER ABOVE - REFER TO PLUMBING DRAWINGS FOR ADDITIONAL INFORMATION.
6 MOVEABLE LINEN BINS WITH LID - TYPICAL OF FOUR (4).
7 HOLD TRASH SURROUND OFF 2" AROUND ADJACENT WALL SURFACES - TYPICAL.
8 ALIGN TRASH SURROUND WITH EDGE OF DOOR.
9 KRONOS TIMECLOCK WILL BE LOCATED 44" A.F.F. TO THE TOP OF UNIT - CENTER KRONOS UNIT IN WALL - REFER TO ELECTRICAL DRAWINGS.
10 ANSUL PULL TO BE LOCATED 48" A.F.F. TO THE CENTER OF UNIT ABOVE THE TIMECLOCK LOCATION.
11 PATIO RAILING LOCATION - SEE SP100 FOR DIMENSIONAL INFORMATION.
12 ELECTRICAL PANEL LOCATION - SEE ELECTRICAL PLANS FOR ADDITIONAL INFORMATION.
13 OFFICE DESK AND SHELVING - REFER TO SHEET A702 AND ELECTRICAL PLANS FOR ADDITIONAL INFORMATION.
14 TELEPHONE BOARD ABOVE - REFER TO ELECTRICAL DRAWINGS FOR ADDITIONAL INFORMATION.
15 MOVEABLE BACK-UP TRASH BINS FOR DINING AREA TRASH SURROUNDS - TYPICAL OF TWO (2).



COPYRIGHT 2024
THIS DRAWING IS AN INSTRUMENT OF SERVICE AND AS SUCH REMAINS THE PROPERTY OF CHIPOTLE MEXICAN GRILL, INC. PERMISSION FOR USE OF THIS DOCUMENT IS LIMITED AND CAN BE EXTENDED ONLY BY WRITTEN AGREEMENT WITH CHIPOTLE MEXICAN GRILL, INC.
PROJECT INFORMATION:

STORE NO.: 5037
HUNTLEY
12990 ROUTE 47, LOT 4B
HUNTLEY, IL 60142

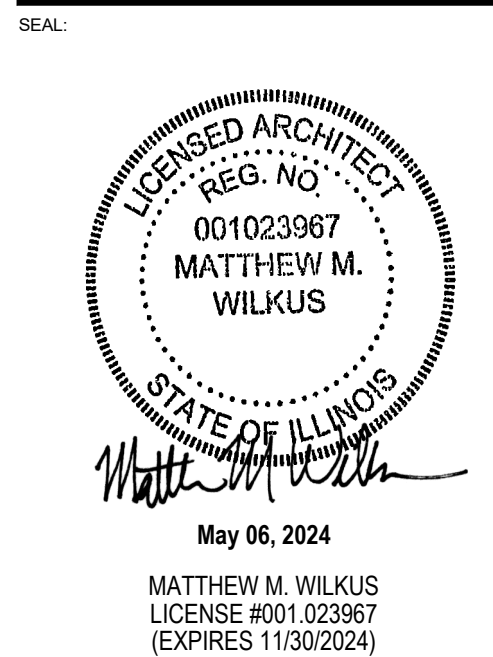

PROJECT NO. 2023-0175
DRAWN BY JSB, DVA
CHECKED BY DVA, NSG, KAM, MMW


ISSUE RECORD:
02/12/2024 PERMIT SUBMITTAL
03/15/2024 BID SET
05/03/2024 CONSTRUCTION SET

REVISIONS:
2 03.15.2024 CITY COMMENTS


TITLE:
FF&E PLAN

SHEET NUMBER:



A130

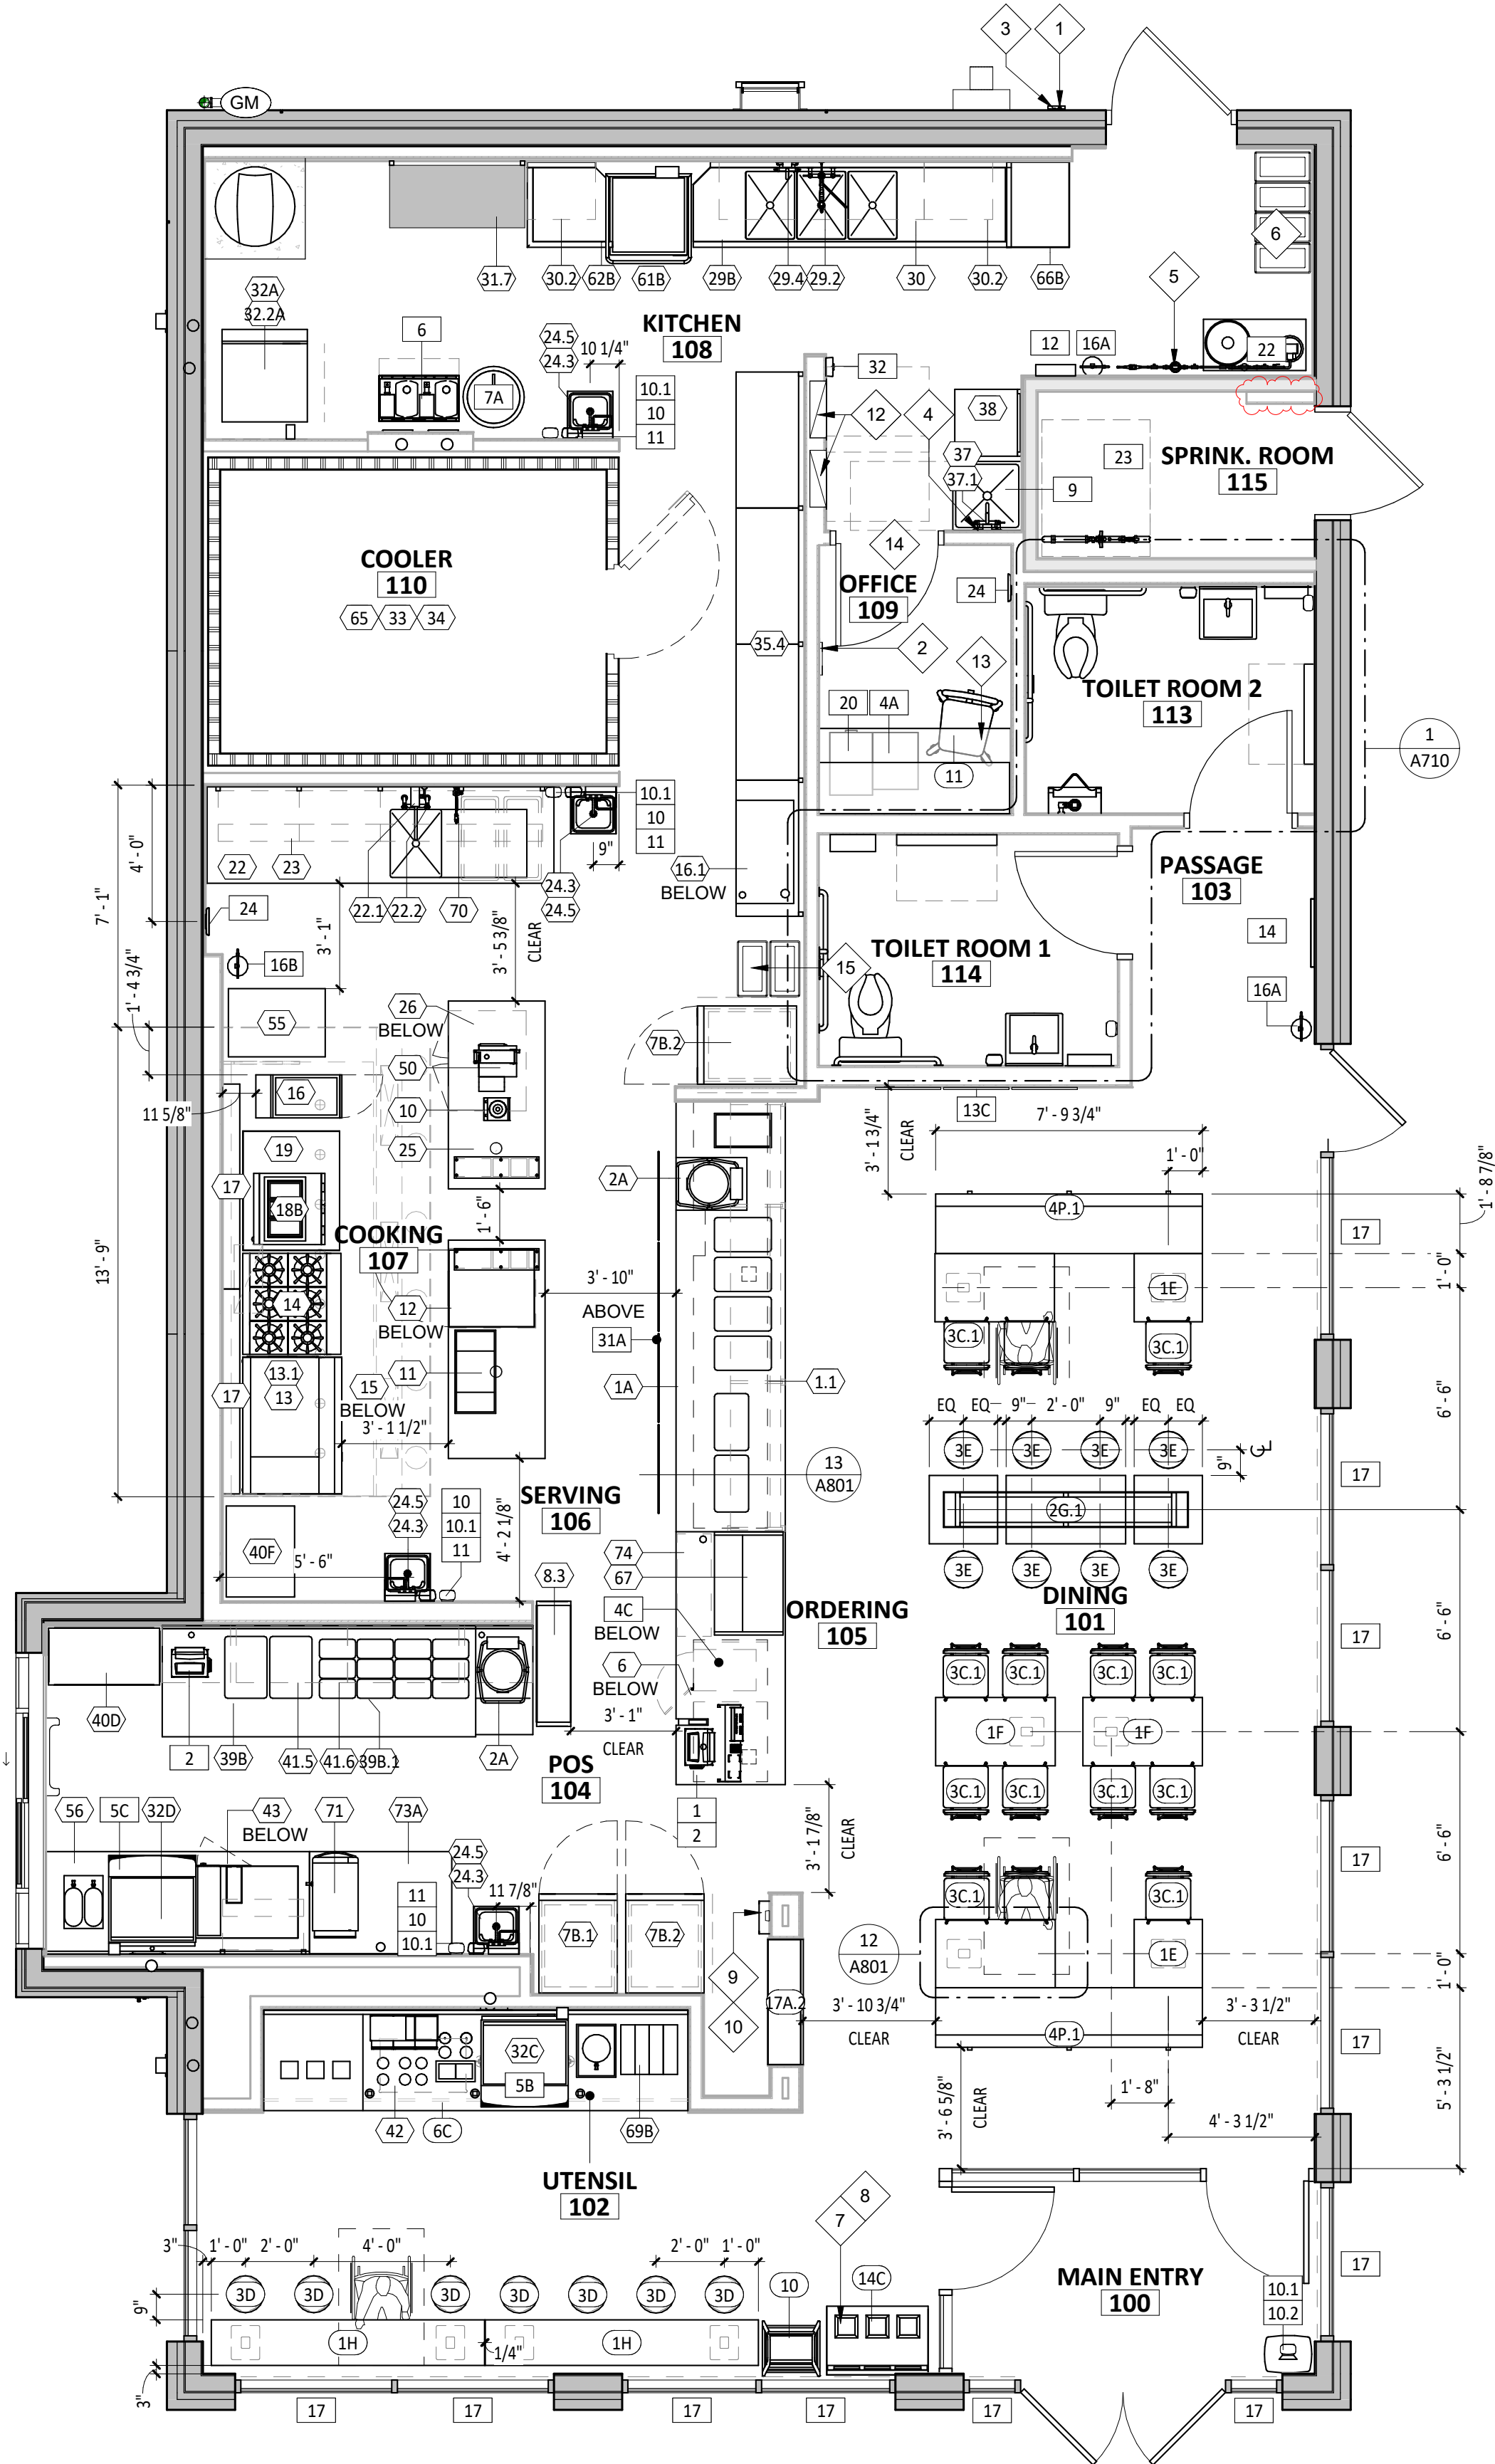

1 FURNITURE, FIXTURE, & EQUIPMENT PLAN
SCALE: 1/4" = 1'-0"

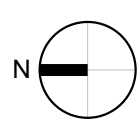

2 FURNITURE, FIXTURE & EQUIPMENT PATIO PLAN
SCALE: 1/4" = 1'-0"

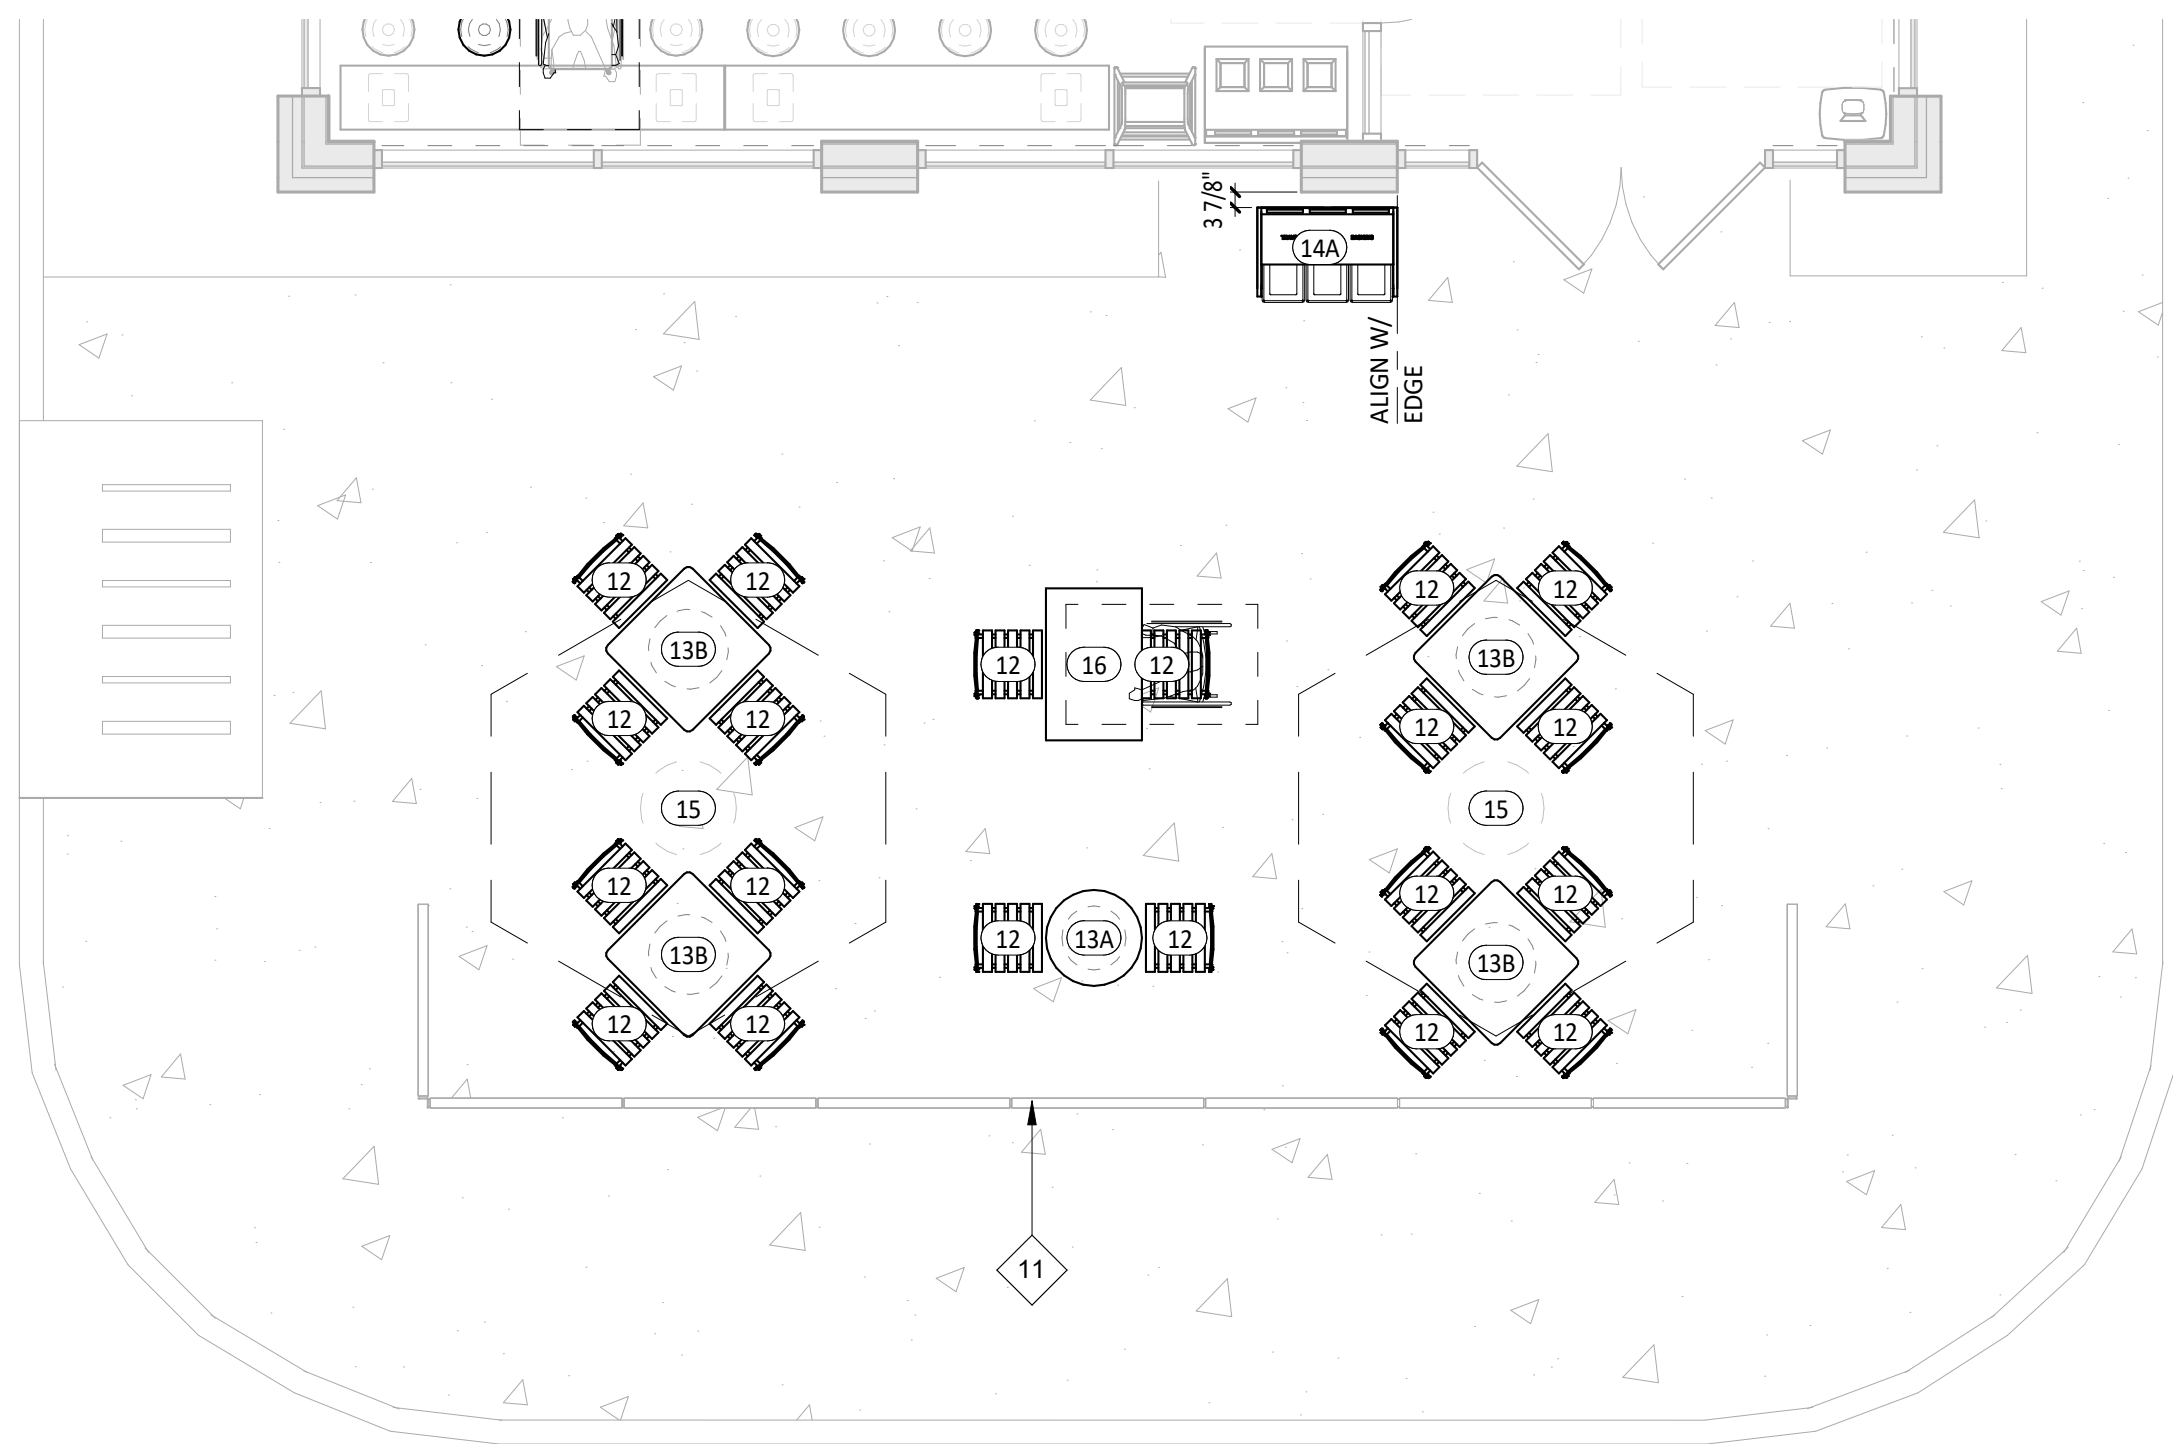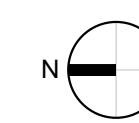

KITCHEN EQUIPMENT LIST

MISC. EQUIPMENT LIST

TAG	DESCRIPTION	MANUFACTURER	MODEL NO.	QTY	FURNISHED BY	INSTALLED BY	UTILITY				REMARKS
							ELEC	GAS	WATER	SEWER	
1.1	Sneeze Guard Serve Line 12 Pan (Right)	BSI	Custom-R	1	TMS	TMS/GC					
1A	M4.0 - Front Serve Line - 12 Pan - RTD - POS Right	Delfield	12 Pan Serve Line POS RTD_241x38.5in (Right)	1	KES	KES; GC	•			•	Installed On Concrete Curb
2A	Tortilla Warmer	Caliente Industries	A2	2	KES	KES	•				GC To Store In Walk-In Cooler Until Final Installation
6	Cup Dispenser	Dispense-Rite	CHIP-ECL-3B	1	KES	KES; GC					Installed At POS Counter
7B.1	Upright Beverage Cooler, Single Door, Hinge Left	Varies	Varies - Solid Door	1	KES	KES	•				
7B.2	Upright Beverage Cooler, Single Door, Hinge Right	Varies	Varies - Solid Door	2	KES	KES	•				
8.3	M4.5 Chip Shelf	Trimark	Custom	1	KES	KES					
10	Blender	Vitamix	748	1	T	T	•				GC To Store In Walk-In Cooler Until Final Installation
11	Carving Station - 77x34in - Horizontal Well - Right	Delfield	77x34in Carving Station-RT	1	KES	KES	•				
12	Undercounter Refrigerator	Hoshizaki	CRM27-LP	1	KES	KES	•				
13	Grill 48in - Natural Gas - Divider Left	Woodstone	WS-PL-48-36-4-CT-Left	1	KES	KES	•	•			
13.1	Woodstone Grease Splash Guard	Nationwide Fab; Marlo Mfg	CHP-GCG-GSG	1	KES	KES					Verify If Required
14	Range 6 Burner - Natural Gas	Garland	U36-6S	1	KES	KES		•			
15	Woodstone Grill Stand 48x31in - Divider Left	Woodstone	000-PL-STAND-CASTER	1	KES	KES					
16	Fryer - Gas - Standard Efficiency	Varies	Varies	1	KES	KES	•	•			Mounted On Legs, G.C. To Pin Front Legs To Floor
16.1	Grease Caddy	Varies	Chipotle Grease Caddy - RH	1	KES	KES					
17	Cook Line Stand Off - 72x6	Nationwide Fab; Marlo Mfg	CHP-GWS-6	2	KES	KES					Mount Top of Flat Surface at 33" AFF, Install Screws at Each Stud Location, Provide Blocking To Mount To Wall
18B	Gas Rice Cooker	Woodstone	WS-GRC-60	1	KES	GC	•	•			Final Connection by GC. RE:Mechanical Drawings
19	Rice Cooker Stand - Left	Nationwide Fab; Marlo Mfg	CHP-RCS-42ES-34	1	KES	KES					
22	Prep Sink - Corner - Left	Trimark	S1-122x34-US-FF-L	1	KES	GC				•	
22.1	Prep Sink Faucet Big Flow Faucet	T&S	B-0293-01	1	KES	GC			•		
22.2	Prep Sink Vegetable Wash Faucet	T&S	B-0730	1	KES	GC			•		GC To Provide Connection For Chemical Dispensing Equipment
22.3	Prep Sink Drain Assembly	T&S	B-3950	1	KES	KES; GC				•	
23	4 Shelves - 120in Prep Sink	Amco	CHPPS120	1	KES	KES					Mount Bottom Of Standard At 50" AFF. Provide Plywood Blocking To Mount To Wall.
23A	2 Shelves - 30in	Amco	Custom	1	KES	KES					Mount Bottom Of Standard At 50" AFF. Provide Plywood Blocking To Mount To Wall.
24.3	Hand Sink Wall Mounted - Splash Both	Universal Stainless	EHS-1RL-NF	4	KES	GC				•	Provide Plywood Blocking To Mount To Wall
24.5	Kitchen Hand Sink Faucet Splash Mount	T&S	B-1146-04-CR-VF10	4	KES	GC			•		Provided with B-0199-06-F10, 1.0 GPM Aerator
25	Rice Prep Table Island 66x34	Nationwide Fabrication; Marlo Mfg	Custom Table 66x34in	1	KES	KES					
26	Hot Holding Cabinet - Double Door (Rice)	Food Warming Equipment (FWE)	HLC-1220-8-8-CHP	1	KES	KES	•				
29.2	Dish Sink Add-A-Faucet w/ Pre-Rinse	T&S	B-1033-12CRBJSK Substitute Sprayer B-0107-J-SWV	1	KES	GC			•		
29.3	Dish Sink Drain Assembly	T&S	B-3950	3	KES	KES; GC				•	
29.4	Dish Sink Chemical Faucet	T&S	B-2345-01-XX	1	KES	GC			•		GC To Provide Connection For Chemical Dispensing Equipment
29B	3 Comp Sink - 18x24in Bowls - 111 3/4in	Nationwide Fabrication; Marlo Mfg	S3-30x111.75x36.5-FF	1	KES	GC				•	
30	Shelving System - 3 Comp Sink	Amco	WST1879S	1	KES	KES					Mount bottom of Standard At 56" AFF. Provide Plywood Blocking
30.2	Shelving System - Dish Table	Amco	WST1879S	2	KES	KES					Mount bottom of Standard At 56" AFF. Provide Plywood Blocking. Mount Tight To Dish Machine
31.7	Drying Racks 23x48x85in - With Vented Aluminum Covers	Varies	Custom	1	KES	KES					Mount Bottom Of Standard At 12" AFF. Provide Plywood Blocking To Mount To Wall
32.1A	Ice Maker - Remote Condenser	Hoshizaki	URC-5F	1	KES	KES	•				Condensing Units To Be Secured To The Roof Per Code By GC
32.1B	Ice Maker - Remote Condenser	Hoshizaki	URC-9F	1	KES	KES	•				Condensing Units To Be Secured To The Roof Per Code By GC
32.2A	Ice Maker - Storage Bin	Hoshizaki	BS005F	1	KES	KES				•	
32.3	Icemaker- Filter	Cuno	Bev 190	3	KES	KES			•		
32.4	Ice Maker - Scale Inhibitor	Cuno	CFS440-HT	3	KES	KES			•		
32.5	Ice Maker - Sanitizer	RGF	IMS8	3	TUV	GC	•				Refer To Installation Guide. When Installed At Utensil Counter, Mount Below Counter In Accessible Location. Refer To Plumbing Drawings.
32A	Ice Maker For B.O.H. Ice Bin (Shorter)	Hoshizaki	KML-700MRJ	1	KES	KES	•		•		Drain Ice Maker to Floor Sink, RE: Mech. Refrigeration By Tenant.
32C	Ice Maker Mounted On Soda Machine - Air Cooled	Hoshisaki	KMD-530MAJ	1	KES	KES	•		•	•	Drain Ice Maker to Floor Sink, RE: Mech. Refrigeration By Tenant.
32D	Ice Maker Mounted On Soda Machine - Remote Air Cooled	Hoshisaki	KMD-530MRJ	1	KES	KES	•		•	•	Drain Ice Maker to Floor Sink, RE: Mech. Refrigeration By Tenant.
33	Walk In Cooler 9x12x9 - 6ft 3in - Standard	Manitowoc	KAMC46-141-1EC-PCL-4	1	WCES	GC	•			•	Refer To Plumbing and Mechanical Drawings; Refrigeration By Tenant; Remote Exterior Compressor Unit To Be Secured To Roof Per Code By GC
34	Walk-In Cooler Shelving System - 9x12x10	Cambro (Cams shelving)	CHP912ER	1	KES	KES					
35.4	Dry Storage Racks 23x19x285in	Varies	Custom	1	KES	KES					Mount Bottom Of Standard At 12" AFF. Provide Plywood Blocking To Mount To Wall.
37	Mop Sink Faucet	T&S	B-0660-BSTR	1	KES	GC			•		
37.1	Mop Sink Chemical Faucet	T&S	B-2345-01-XX	1	KES	GC			•		GC To Provide Connection For Chemical Dispensing Equipment
38	6 Shelves - Chemical Storage Rack	Varies	Custom	1	KES	KES					Mount Bottom Of Standard At 12" AFF. Provide Plywood Blocking To Mount To Wall.
39B	DML 2.0 130in – Right – W/POS & Cash Drawer	Franke/Delfield	DML 2.0_RT-130x39	1	KES	KES	•			•	
39B.1	DML 2.0 Wall Trim Package	Franke/Delfield	DML 2.0 Trim Kit	1	KES	KES					
40D	Holding Shelf	Trimark	TGS-39X20X80-B	1	KES	KES	•				
40F	M4.5 - Filler Stand At Range	Select Stainless	24x32x36	1	KES	KES					
41.5	DML 2.0 Shelving - 130in - Top Shelf	Franke/Delfield	CH000A32	1	KES	KES					Mount Bottom Of Shelf At 74 1/2" AFF. Provide Plywood Blocking To Mount To Wall.
41.6	DML 2.0 Shelving - 130in - Bottom Shelf	Franke/Delfield	CH000A34	1	KES	KES					Mount Bottom Of Lowest Portion Of Shelf At 54 1/2" AFF. Provide Plywood Blocking To Mount To Wall.
42	Shelving System Under Counter Beverage Station	ISS	WST181OCLR	1	KES	KES					Mounted on (4) casters, All casters to be swivel type, Front (2) casters to have brake, Located under utensil counter
43	Beverage Cooler Backbar 36in	Glasstender	LP36X-SS(X)	1	KES	KES	•				
45	Dunnage Rack - 18x36in	ISS	AAL361812	1	KES	KES					
50	Food Processor	Sammic	CA-31	1	KES	KES					
55	Filler Table - 24x34in	Trimark	TS-24x34x36-US-C	1	KES	KES					
56	Beverage Table - Chipotlane	Trimark	TS-36x92.5x36	1	KES	GC	•			•	
61B	Dish Machine (w/Pump)	Hobart	AM165CB	1	KES	KES	•		•	•	
62B	Dish Table 30x30	Babington Technology	CDT-30X30X36.5-B-L	1	KES	GC					
65	Utility Cart (Not Shown)	Select Stainless	30SU-22-14-C4-TUBS-CUSTOM	1	KES	GC					Provided As Part Of The WIC Shelving
66B	Drop-Off Table - 22x30in	Trimark	TS-22x30x31-US-C	1	KES	KES					
67	Refrigerated Counter Case, Self-Serve	Structural Concepts	CO3324R-UC	1	KES	KES					
69B	M4.0 - Simplicity Bubbler Mini-Quad	Crathco	CS-4E-16	1	KES	GC	•			•	
70	Speed Fill Faucet	T&S	B-0432 MOD	1	KES	GC			•		
71	Quesadilla Press	Turbochef	Sota Touch	1	KES	KES	•				
73A	50" TurboChef Table	Trimark	50X36X36	1	KES	KES					
74	Shelving - Under Counter - 12x36x29in	Metro	Custom	1	KES	KES					

TAG	DESCRIPTION	QTY	FURNISHED BY	INSTALLED BY	ELEC	GAS	WATER	SEWER	REMARKS
1	Point of Sale Display	1	TMS	GC					Installed at POS Station
2	Point-Of-Sale System	2	T	TCC					Coordinate Requirements With Tenant and Elec. Drawings
4A	B-Rate (Standard Safe)	1	TS	GC					Install in Office, Bolt to Office Floor Slab
4C	Smart Safe	1	TSS	TSS	●				To Be Installed On Curb Under Serveline, Bolt to Curb Under Serveline POS
5B	Soda Dispenser - With Air-Cooled Ice Maker	1	SPS	SPS	●			●	Drain to Floor Sink, Tenant Millwork Supplier to Provide (2) Adjustable Legs to Support Dispenser From Under The Utensil Counter
5C	Soda Dispenser - With Remote Air-Cooled Ice Maker	1	SPS	SPS	●			●	Drain to Floor Sink, Tenant Millwork Supplier to Provide (2) Adjustable Legs to Support Dispenser From Under The Utensil Counter
6	Soda System Syrup Rack with Carbonator on Stainless Steel Shelf	1	SPS	SPS	●		●		
7A	Bulk CO2 Tank	1	CO2	CO2	●				GC To Secure Cylinders To Wall With Grade 30 Galvanized Steel Chain At 2/3 The Height Of The Cylinder. Attach To Wall With Stainless Steel Quick Link And Screw Eye.
8B	Gas Water Heater	1	WHS	GC	●	●	●	●	Drain Water Heater to Floor Sink, RE: Mech.
9	Mop Sink, See Plumbing Drawings	1	GC	GC			●	●	See Plumbing Drawings
10	Touch-Free Soap Dispenser	4	WA	GC					
10.1	Hand Sanitizer Dispenser	5	WA	GC					
10.2	Hand Sanitizer Stand	1	WA	GC					
11	Paper Towel Dispenser, Bobrick B262	4	WA	GC					Provide Plywood Blocking to Mount to Wall
12	First Aid Kit	1	T	GC					Confirm Location With Chipotle CM Prior To Installation
13C	M4.0 - Artwork Panel - Carved Rice Board	1	TAS	GC					Provide Plywood Blocking to Mount to Wall
14	License Frame	1	T	GC					Provide Plywood Backing In Wall At License Frame Location, Refer To Arch. Floor Plans And Elevations For License Frame Location.
16A	Fire Extinguisher Type ABC - B456	2	GC	GC					Mount in locations specified by the Fire Marshal. Provide plywood backing at specified locations.
16B	Fire Extinguisher Type K	1	GC	GC					Mount in locations specified by the Fire Marshal. Provide plywood backing at specified locations.
17	Window Shades	12	WS	WS					See Sheet A130 For Location & Size (When Used)
19	Hat & Coat Strips (Not Shown)	1	WA	GC					Provide Plywood Blocking to Mount to Wall
20	2-Drawer File Cabinet, By Tenant	1	T	T					By Tenant
22	Water Softener	1	KES	GC			●	●	See MEP Sheets For Details
23	Backflow Preventer	1	GC	GC			●	●	See MEP Sheets for Details
24	iPAD Wall Station	4	T	GC	●				Tablet By Tenant, Refer to Electrical Drawings
28	Mop Strip (Not Shown)	1	T	GC					Provide Plywood Backing To Mount To Wall, 2 Hole At Mop Basin and 6 Hole In Kitchen
31A	21mx31in Menu System	1	TMB	GC					
32	CO2 Alarm	1	CO2AS	GC	●				Refer to Electrical Drawings for Additional Details.
33A	M4.0 - Pick-Up Sign - Single Faced - Flush Mounted - Face	1	TSV	GC					

FURNITURE LIST

TAG	DESCRIPTION	QTY	FURNISHED BY	INSTALLED BY	UTILITY			REMARKS
					GAS	WATER	SEWER	
1E	M4.0 - Table 24x24in - Rectangular Base	2	TMS	GC				
1F	M4.0 - Table 24x42in, Rectangular Base (Accessible)	4	TMS	GC				See Detail On A130
1H	M4.0 - Community Table - Low - Window - Length Varies	2	TMS	GC				
2G.1	M4.0 - Bar Height Table 8-Top, With Footrest	1	TMS	GC				One Coat Hook Per Two Seats, Confirm Mounting Location With Shop Drawings
3C.1	M4.0 - Dining Room Chair	15	TMS	GC				
3D	M4.0 - Marshmallow Stool - Fixed	7	TMS	GC				Align Seat With Seam Perpendicular To Table Edge
3E	M4.0 - Bar Stool - Fixed	8	TMS	GC				Align Seat With Seam Perpendicular To Table Edge
4P.1	Banquette Bench (Black) - Floor Mount	2	TMS	GC				
6C	M4.0 - Beverage Counter - With Trash - 4" Splash - 149"	1	TMS	GC				Coordinate Floor Drain Installation with Utensil Counter Installation, Bins Provided by Tundra in Smallwares Package
10	Child's High Chair	1	T	GC				
11	Office Chair, By Tenant	1	T	T				By Tenant
12	Patio Chair - Bistro	20	KES	GC				Provided by EMU America, Contact: Carol Hughes (303-744-3200)
13A	24in Round Bistro Table	1	KES	GC				Provided by EMU America, Contact: Carol Hughes (303-744-3200)
13B	30in Square Bistro Table	4	KES	GC				Provided by EMU America, Contact: Carol Hughes (303-744-3200)
14A	3 Bin Trash/Recycling Surround - Exterior	1	TMS	GC				Bins Provided by Tundra in Smallwares Package
14C	M4.0 - 3 Bin Trash/Recycling Surround - Interior	1	TMS	GC				Bins Provided by Tundra in Smallwares Package
15	Patio Umbrella	2	KES	GC				
16	Accessible Patio Table	1	KES	GC				Provided by EMU America, Contact: Carol Hughes (303-744-3200)
17A.2	MOPUS Shelving - 44"	1	TMS	GC				GC To Provide Blocking In Walls At The Ends Of The MOPUS Shelf To Secure Shelves, Wood Edge Of The Shelves To Face The Dining Room

CONSULTANT



CLIENT



CHIPOTLE MEXICAN GRILL, INC.
PO BOX 182566
COLUMBUS, OH 43218-2566
TELEPHONE: (614) 318-2482
INTERNET: WWW.CHIPOTLE.CO


COPYRIGHT 2024
THIS DRAWING IS AN INSTRUMENT OF SERVICE AND
AS SUCH REMAINS THE PROPERTY OF CHIPOTLE
MEXICAN GRILL, INC.. PERMISSION FOR USE OF THIS
DOCUMENT IS LIMITED AND CAN BE EXTENDED ONLY
BY WRITTEN AGREEMENT WITH CHIPOTLE MEXICAN
GRILL, INC..

PROJECT INFORMATION

STORE NO.: 5037

HUNTLEY
12990 ROUTE 47, LOT 4B
HUNTLEY, IL 60142

SEAL

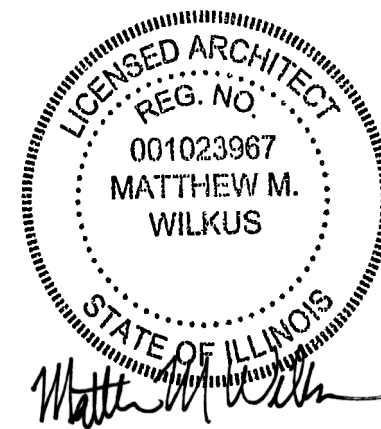

May 06, 2024

MATTHEW M. WILKUS
LICENSE #001.023967
(EXPIRES 11/30/2024)

PROJECT NO. 2023-0175

DRAWN BY JSB, DVA

CHECKED BY DVA, NSG, KAM, MMW

ISSUE RECORD

02/12/2024 PERMIT SUBMITTA

03/15/2024	BID SET
------------	---------

05/03/2024	CONSTRUCTION S
------------	----------------

REVISIONS

TITLE


FF&E SCHEDULES

SHEET NUMBER

A131


1 ROOF PLAN

SCALE: 1/4" = 1'-0"

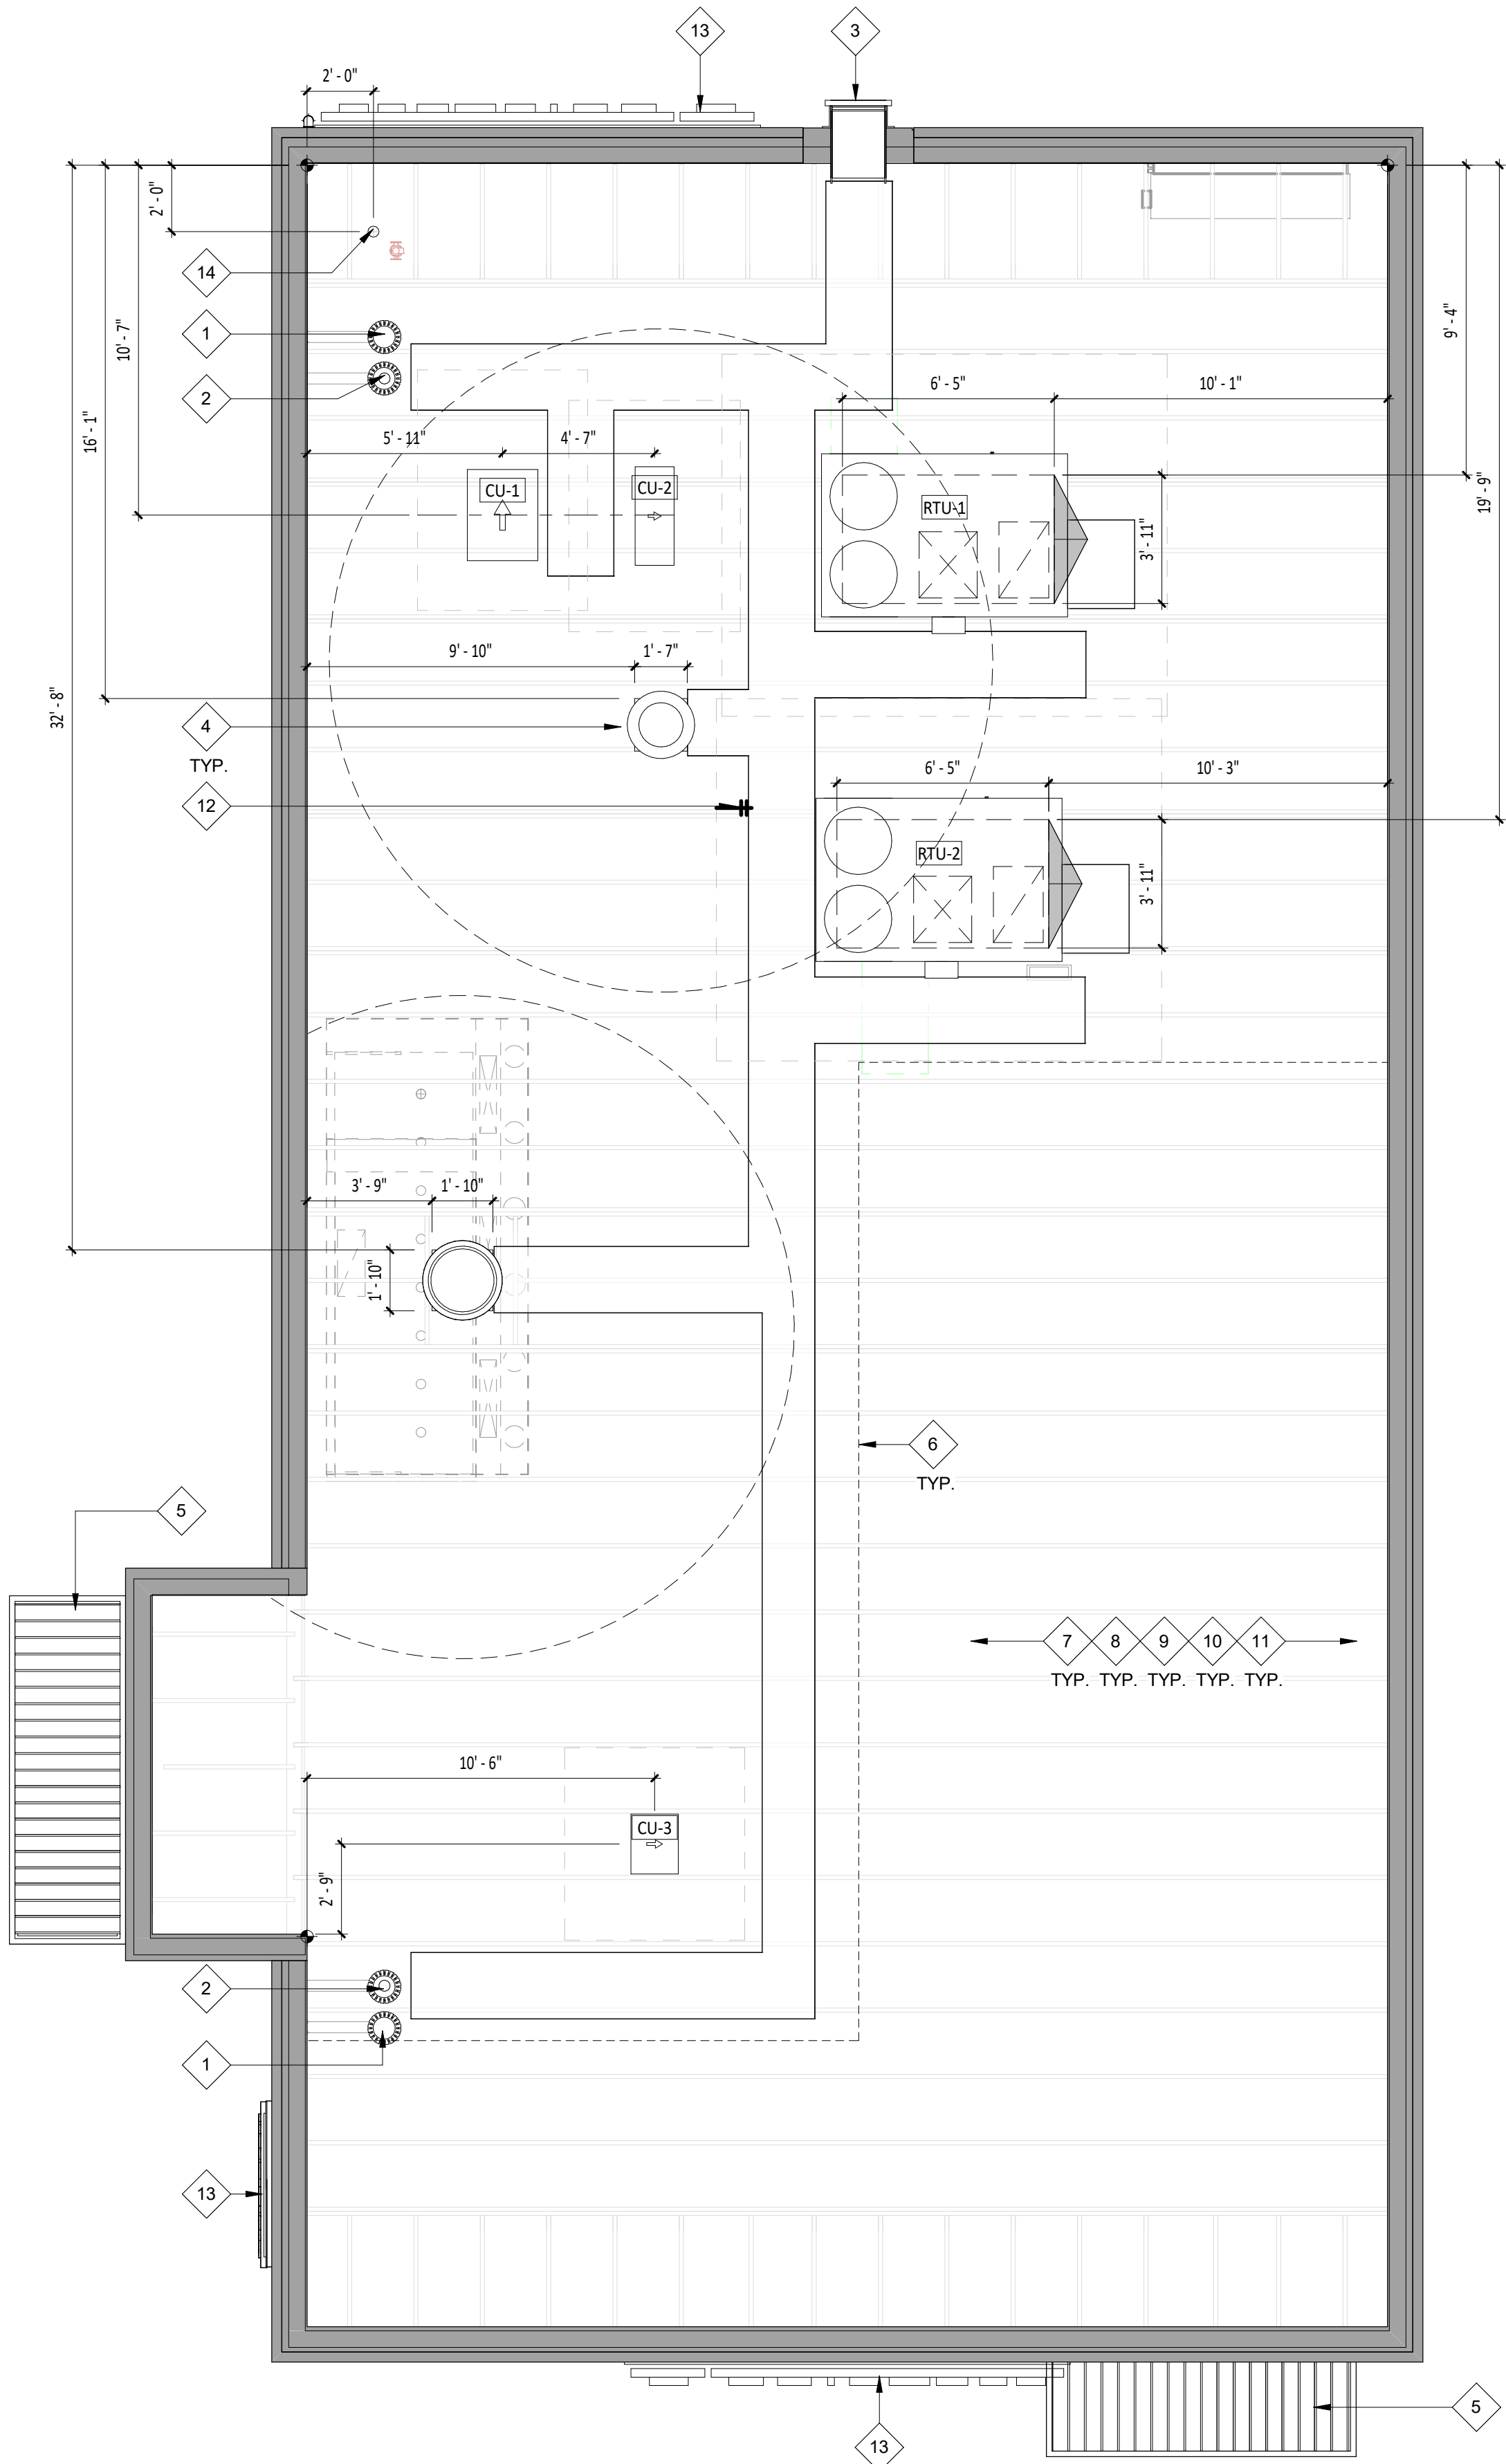

HVAC EQUIPMENT

DESCRIPTION	FURNISHED BY	INSTALLED BY	UTILITY				REMARKS
			ELEC	GAS	WATER	SEWER	
Exhaust Fans & Curbs	HS	GC	•	•			Curb furnished by HS, installed by GC
Make Up Air Unit & Curbs	HS	GC	•	•	•	•	Curb furnished by HS, installed by GC
Roof Top Units & Curbs	HES	GC	•	•	•	•	Curb furnished by HS, installed by GC
Test & Balance System	TAB	-	•	•	•		Furnish HVAC Test & Balance per Tenant's National Account Program.

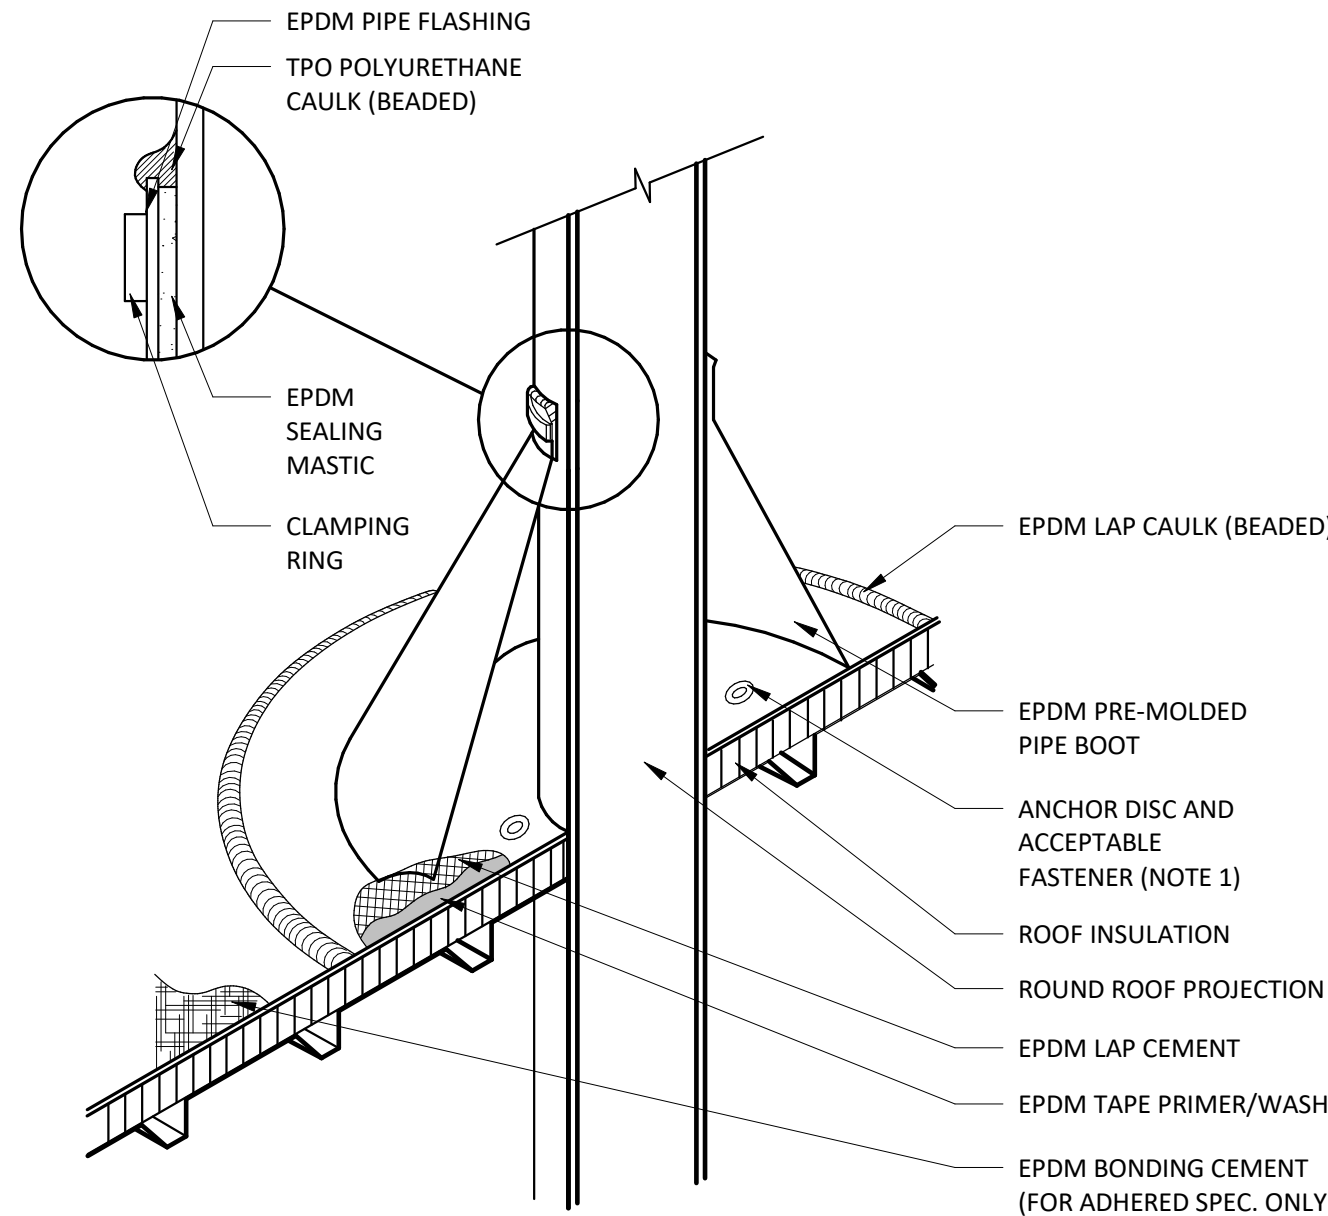


NOTE:

- WITH MECHANICALLY FASTENED OR BALLASTED SPECIFICATIONS, MEMBRANE MUST BE MECHANICALLY ATTACHED WITH 2" (50 mm) ANCHOR DISC AND ACCEPTABLE FASTENERS (MINIMUM OF 4 PER PIPE).
- DO NOT OVERLAP THE FLANGES FROM ADJACENT PIPE FLASHINGS.
- ANY SEAM UNDER BOOT FLANGE TO BE TREATED AS T-JOINT.
- BOTH SURFACES TO BE MATED MUST BE CLEANED WITH TAPE PRIMER/WASH. EPDM TAPE PRIMER/WASH MUST BE COMPLETELY DRY AND TACK FREE BEFORE APPLYING EPDM LAP CEMENT.

2 BOOT DETAIL

SCALE: 1/2" = 1'-0"

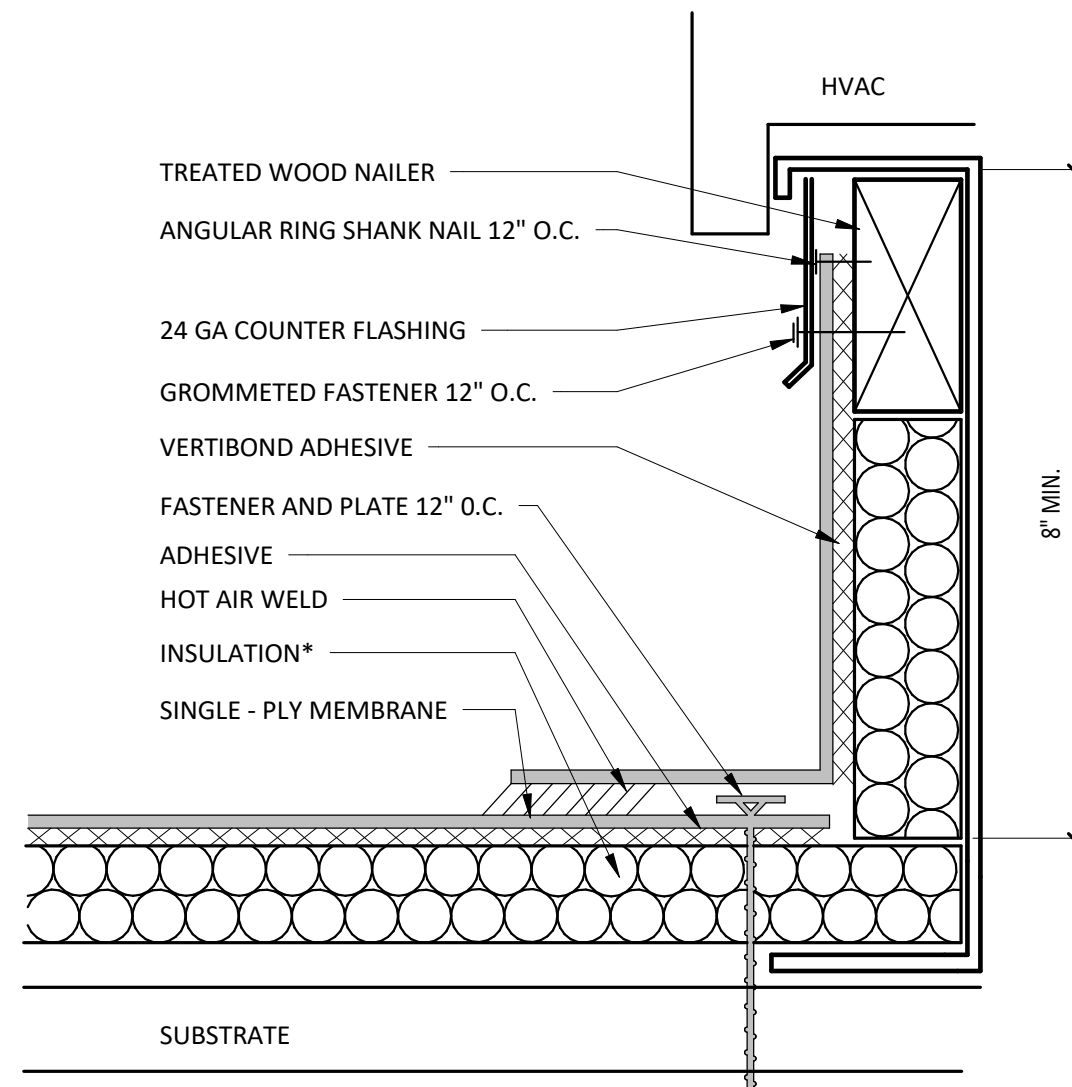

NOTES:

- INSTALLATION TO BE COMPLETED IN ACCORDANCE WITH MANUFACTURERS SPECIFICATIONS.
- DO NOT SCALE DRAWINGS.
- USE PREFABRICATED OUTSIDE CORNERS.
- INSULATION MUST BE SECURELY FASTENED.
- *GLASS - FACED POLYISO INSULATION IS OPTIONAL AND MAY NOT BE REQUIRED ON EVERY PROJECT. IF INSULATION IS NOT REQUIRED, THE MEMBRANE MUST BE ADHERED TO AN APPROVED SURFACE.

3 CURB FLASHING

SCALE: 1/2" = 1'-0"

GENERAL NOTES - ROOF PLAN

- SEE STRUCTURAL DRAWINGS FOR LOCATIONS AND SIZE OF STRUCTURAL ROOF REINFORCEMENTS.
- SEE MECHANICAL PLANS FOR ROOFTOP EQUIPMENT.
- COORDINATE ALL ROOF PENETRATIONS, FLASHING, AND REPAIR W/ CHIPOTLE CONSTRUCTION MANAGER PRIOR TO COMMENCEMENT OF WORK - SEE 2/A140
- DIMENSIONS FOR ROOFTOP EQUIPMENT WITH CURBS IS TO THE OUTSIDE FACE OF CURB. DIMENSIONS FOR EQUIPMENT WITHOUT CURBS ARE TO THE CENTER OF THE UNIT. ALL DIMENSIONS ARE FOR REFERENCE ONLY. ROOFING CONTRACTOR TO ADJUST AS NECESSARY IN FIELD. CONTACT ENGINEERING CONSULTANTS FOR ANY MAJOR MODIFICATIONS TO LAYOUT.
- JOISTS FOR SHELL BUILDING WERE DESIGNED FOR THE RTU WEIGHTS AND PLACEMENT EXHIBITED. IF LOCATION OR ORIENTATION OF A UNIT MUST CHANGE, NOTIFY ARCHITECT IMMEDIATELY.
- SEE M700 FOR PENETRATION DETAILS AT RTUS AND THE EXHAUST FAN.
- PROVIDE INSULATED CURBS FOR ALL EQUIPMENT IN EXPOSED DECK AREA ONLY - SEE 3/A140
- PROVIDE TAPERED INSULATED CRICKET AT ALL EQUIPMENT CURBS.
- LOCATE ALL UNITS SO DUCT DROPS BETWEEN TRUSS JOISTS. NOTIFY ARCHITECT IMMEDIATELY IF ANY UNITS NEED TO SHIFT FROM PLAN LOCATION SHOWN.

KEYNOTE LEGEND

- OVERFLOW ROOF DRAIN LOCATION - GENERAL CONTRACTOR IS RESPONSBLE OF SNAKE CLEANING PRIOR TO BUILDING TURNOVER.
- PRIMARY ROOF DRAIN LOCATION - GENERAL CONTRACTOR IS RESPONSBLE OF SNAKE CLEANING PRIOR TO BUILDING TURNOVER.
- EXISTING ROOF LADDER LOCATION.
- ROOF TOP WALKING PADS PER MANUFACTURERS RECOMMENDATIONS - TYPICAL.
- CANOPY BELOW - REFER TO EXTERIOR ELEVATIONS.
- HIDDEN LINE INDICATES SOFFIT LOCATION BELOW IN WHICH TERMINATES TO UNDERSIDE OF EXISTING DECK.
- EXISTING FULLY ADHERED PVC ROOFING SYSTEM AND RIGID INSULATION - PATCH AND REPAIR AS REQUIRED - REFER TO SPECIFICATIONS FOR ADDITIONAL INFORMATION.
- EXISTING WOOD JOISTS BELOW SHOWN FOR REFERENCE ONLY - REFER TO STRUCTURAL DRAWINGS FOR ADDITIONAL INFORMATION.
- ALL ROOF PENETRATIONS, INCLUDING MINOR ROOF VENTS AND SIMILAR ITEMS, MAY NOT BE INDICATED ON PLAN - GENERAL CONTRACTOR TO VERIFY AND COORDINATE SCOPE SO AS TO INDICATE ALL ROOFING AND FLASHING WORK SO AS TO OBTAIN AND/OR MAINTAIN EXISTING ROOFING WARRANTIES.
- LOCATIONS OF ALL ROOF PENETRATIONS ARE TO BE VERIFIED WITH APPROPRIATE SUBCONTRACTOR.
- GENERAL CONTRACTOR TO CLEAN ROOF OF ALL CONSTRUCTION DEBRIS AT PROJECT COMPLETION.
- ROOF HYDRANT - REFER TO PLUMBING FOR ADDITIONAL INFORMATION.
- SIGNAGE BY TENANTS VENDOR - GENERAL CONTRACTOR TO PATCH AND REPAIR ADJACENT WALL AS REQUIRED FOR SIGN INSTALLATION - GENERAL CONTRACTOR TO COORDIANTE SIGNAGE PENETRATIONS WITH SIGNAGE VENDOR.
- THROUGH-ROOF CONDUIT FOR CELL BOOSTER - REFER TO ELECTRICAL DRAWINGS FOR ADDITIONAL INFORMATION.

CONSULTANT:



CLIENT:




COPYRIGHT 2024
THIS DRAWING IS AN INSTRUMENT OF SERVICE AND AS SUCH REMAINS THE PROPERTY OF CHIPOTLE MEXICAN GRILL, INC. PERMISSION FOR USE OF THIS DOCUMENT IS LIMITED AND CAN BE EXTENDED ONLY BY WRITTEN AGREEMENT WITH CHIPOTLE MEXICAN GRILL, INC.

PROJECT INFORMATION:

STORE NO.: 5037
HUNTLEY
12990 ROUTE 47, LOT 4B
HUNTLEY, IL 60142

SEAL:

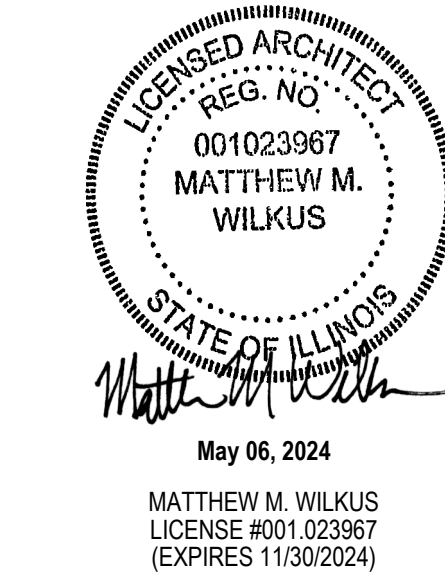

PROJECT NO. 2023-0175
DRAWN BY JSB, DVA
CHECKED BY DVA, NSG, KAM, MMW

ISSUE RECORD:
02/12/2024 PERMIT SUBMITTAL
03/15/2024 BID SET
05/03/2024 CONSTRUCTION SET


REVISIONS:

TITLE:

ARCHITECTURAL
ROOF PLAN

SHEET NUMBER:

A140

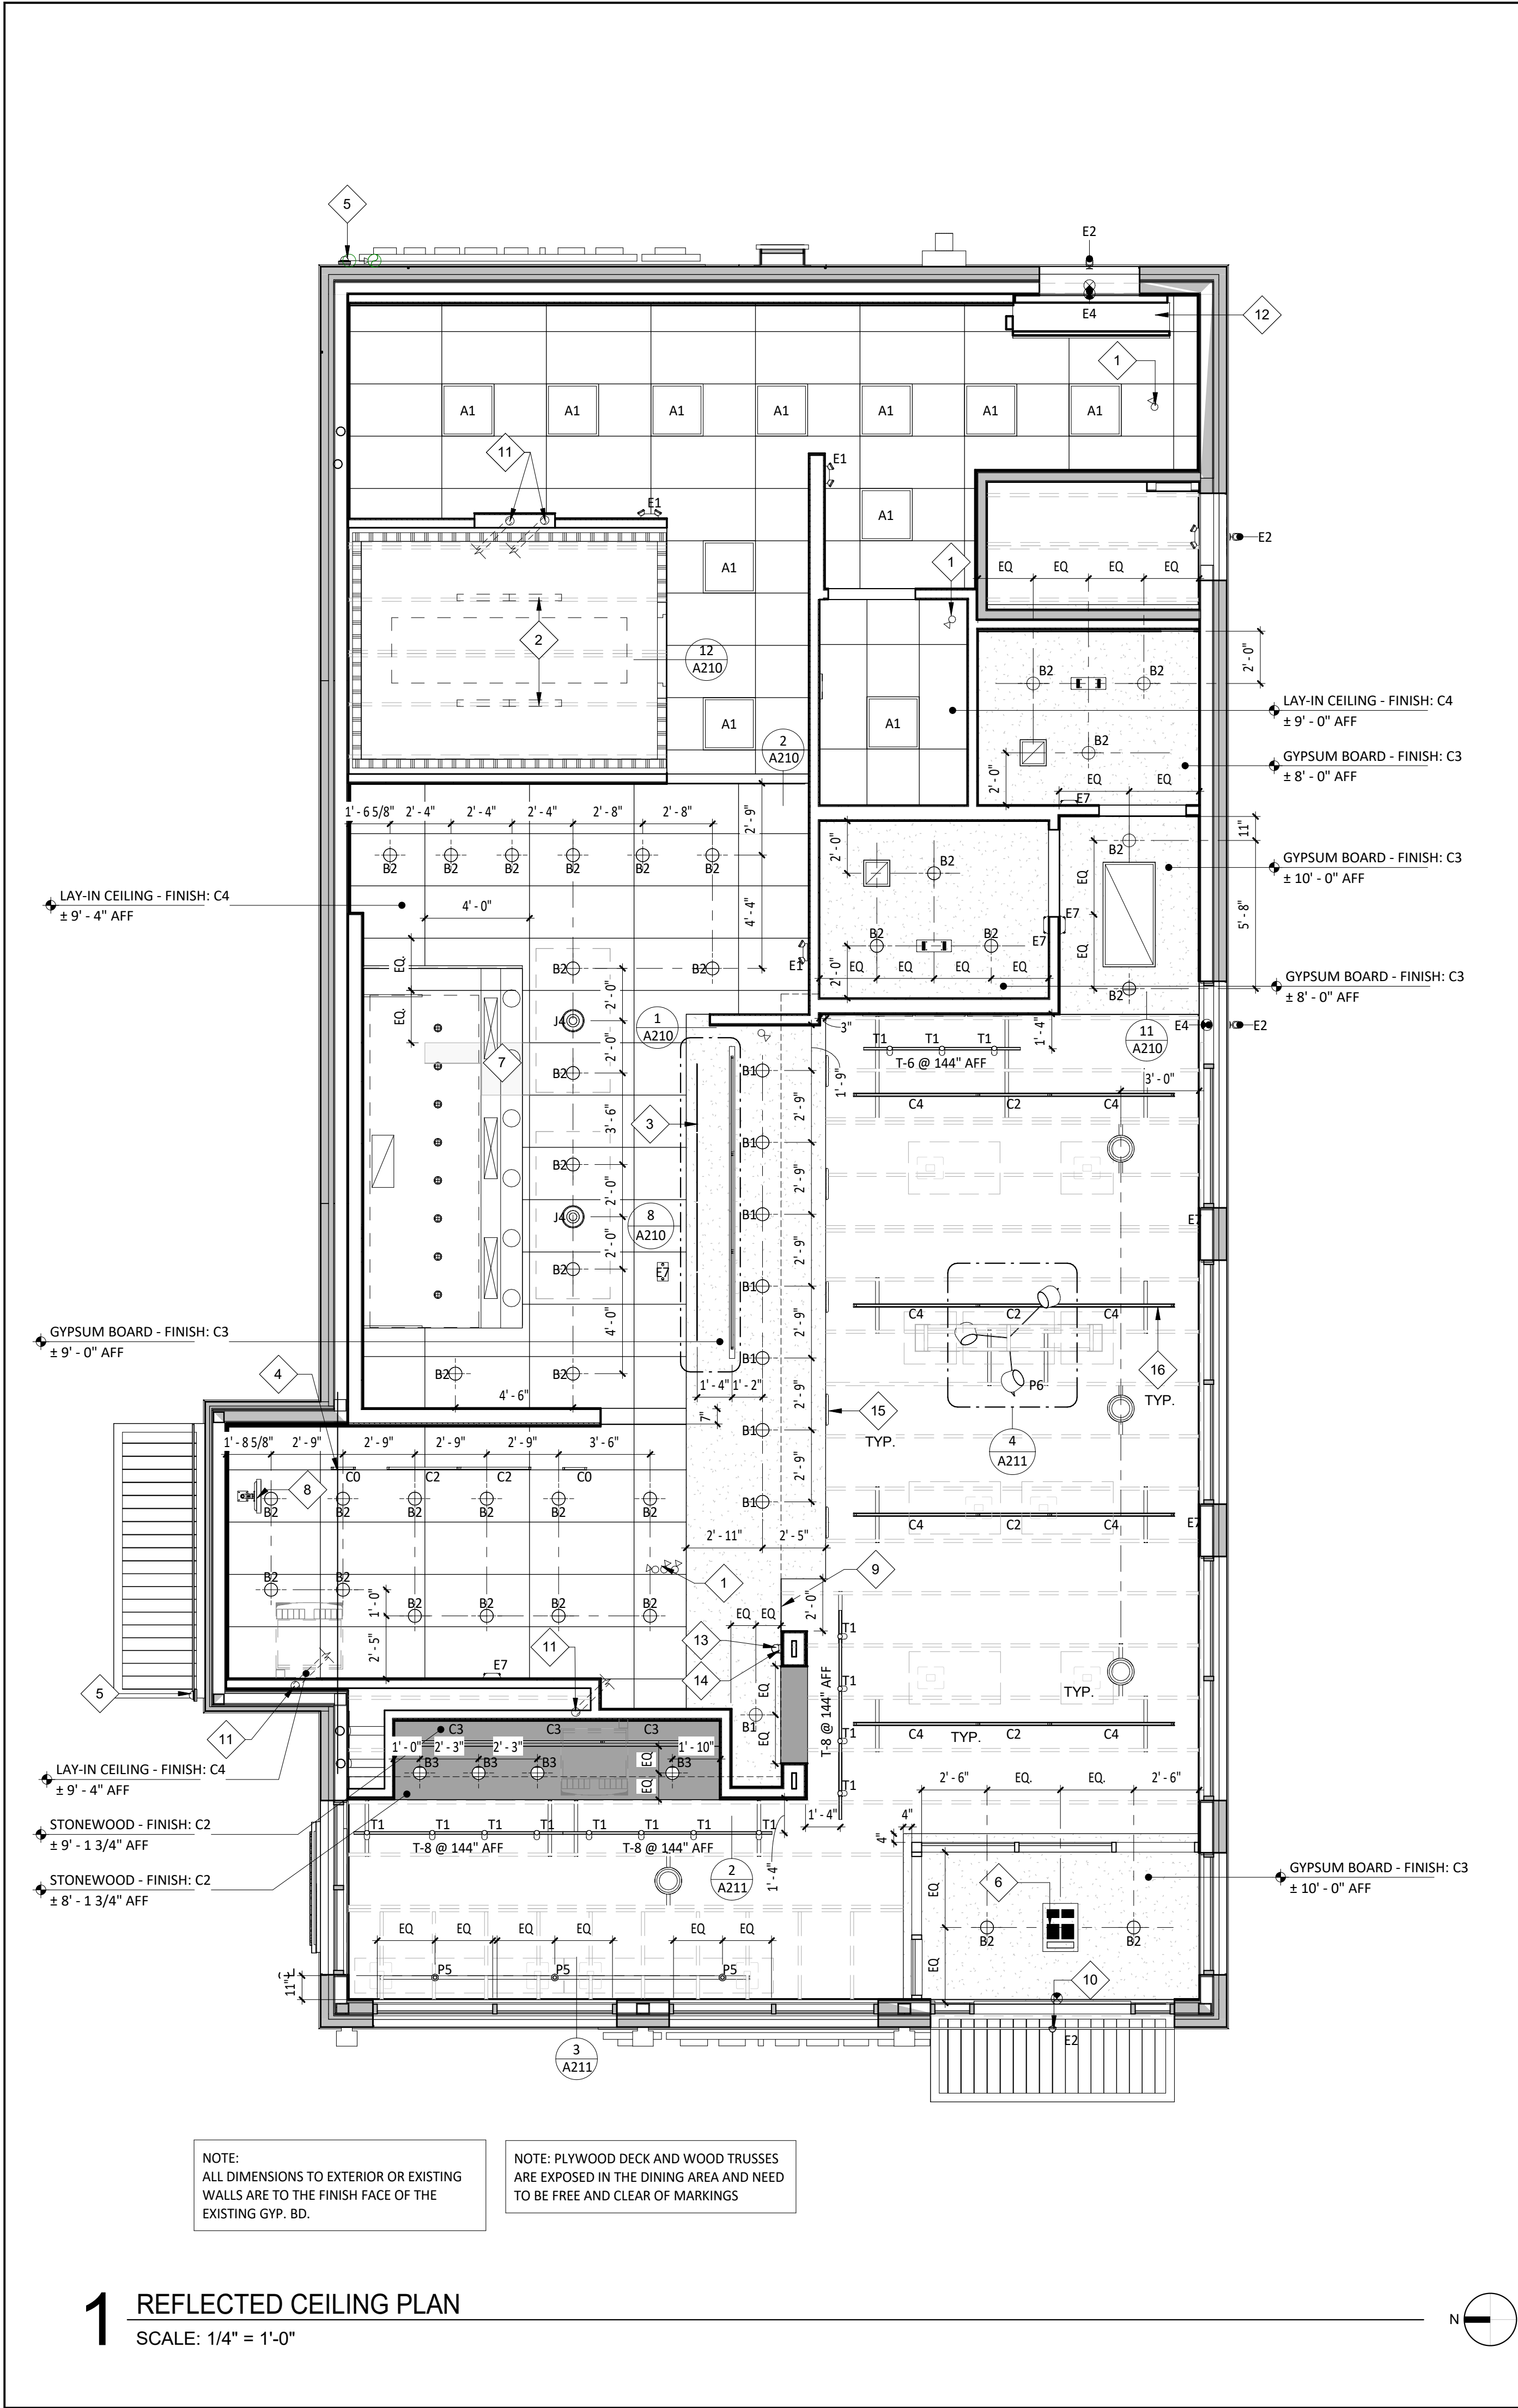

LIGHTING FIXTURE SCHEDULE

ITEM #	MOUNT	DESCRIPTION	REMARKS
EXISTING			
(E)X9	SURFACE	LED CHANNEL LIGHT BY LANDLORD	SEE SHEET E100
NEW			
A1	LAY-IN	2x2 LED LENSED TROFFER	SEE SHEET E100
B1	CEILING	RECESSED 6IN CAN LIGHT	SEE SHEET E100
B2	CEILING	RECESSED 6IN CAN LIGHT	SEE SHEET E100
B3	CEILING	M4.0 - RECESSED 6IN CAN LIGHT (BLACK)	SEE SHEET E100
C0	SURFACE	LOW PROFILE LED 1FT	SEE SHEET E100
C2	SURFACE	LOW PROFILE LED 3FT	SEE SHEET E100
C3	SURFACE	LOW PROFILE LED 4FT	SEE SHEET E100
C4	SURFACE	LOW PROFILE LED 5FT	SEE SHEET E100
E1	VARIOUS	EMERGENCY LIGHT - DUAL HEAD	SEE SHEET E100
E2	VARIOUS	EMERGENCY LIGHT - SINGLE HEAD	SEE SHEET E100
E7	VARIOUS	EMERGENCY LIGHT - DUAL HEAD	SEE SHEET E100
H1	SURFACE	VAPOR PROOF HOOD LIGHT	SEE SHEET E100
J4	PENDANT	M4.0 - PENDANT LIGHT	SEE SHEET E100
P5	PENDANT	PENDANT LIGHT	SEE SHEET E100
P6	PENDANT	M4.0 - MULTI-PENDANT LIGHT	SEE SHEET E100 & A701
T1	TRACK	TRACK LIGHTING HEAD	SEE SHEET E100
T-6	SUSPENDED	M4.0 - TRACK 6'	SEE SHEET E100
T-8	SUSPENDED	M4.0 - TRACK 8'	SEE SHEET E100

GENERAL NOTES - RCP

- ALL INTERIOR LIGHT FIXTURES AND LAMPS PROVIDED BY TENANT'S LIGHT/LAMP SUPPLIER.
- ALL INTERIOR LIGHT FIXTURES AND LAMPS INSTALLED BY GC. CAREFULLY REVIEW LIGHTING FIXTURE SCHEDULE ON SHEET E100.
- KITCHEN EXHAUST HOOD PROVIDED BY HS AND INSTALLED BY GC. GC TO COORDINATE PRESSURE TEST AND VIRO GUARD WITH ENVIROMATIC, INC.
- ANSUL BOX & FIRE SUPPRESSION SYSTEM PROVIDED BY AND INSTALLED BY HS. HOOD INTERLOCK BY GC. ELECTRICAL CONNECTION BY GC, RE: ELEC.
- MENU BOARD ASSEMBLY PROVIDED BY TMB, INSTALLED BY G.C.
- PROVIDE BLOCKING ABOVE MENU BOARD ASSEMBLY FOR INSTALLATION.
- REFER TO "09900 PAINTING - GENERAL" IN SPECIFICATIONS FOR FINISHES AT EXPOSED CEILING AREAS IN ADDITION TO NOTES LISTED ON THIS SHEET AND A120
- UNISTRUT TO BE LEFT UNPAINTED. PROVIDE MATCHING CLOSER STRIPS AND END CAPS. CLOSER STRIP TO BE APPLIED TO THE UNDERSIDE OF THE UNISTRUT.
- ALL HEIGHTS ARE TO BOTTOM OF FIXTURE UNLESS NOTED OTHERWISE.
- LIGHT DETAILS ARE LOCATED ON SHEET A210. FIXTURE AND LAMP SPECIFICATIONS ARE LOCATED ON E100.
- ALL UNISTRUT SUPPORTING CEILING ELEMENTS AND/ OR DUCT WORK SHALL NOT CONTAIN ANY ELECTRICAL CONDUIT. ALL ELECTRICAL CONDUIT MUST RUN IN SEPARATE UNISTRUT.
- ALL UNISTRUT, CONDUIT, SPRINKLER & WATER LINES SHALL BE INSTALLED TO THE BOTTOM OF THE DECK OR AS SHOWN IN DETAILS & LEFT UNPAINTED.
- ALL DIMENSIONS ARE TO FACE OF FRAMING, OR CENTERLINE OF FIXTURE UNLESS NOTED OTHERWISE.
- SEE ELECTRICAL DRAWINGS FOR SHATTER RESISTANT LAMP LOCATIONS.
- ALL EMERGENCY FIXTURES, LIGHTS AND STROBES SHALL BE ALIGNED OR CENTERED ON WALLS.
- FULL CERAMIC TILE COURSING SHALL TAKE PRECEDENT OVER ANY CEILING/HEADER DIMENSION INDICATED IN THE PLAN, REFER TO A120.
- ALL CONDUIT AND PIPE PENETRATIONS OF THE SERVING LINE SOFFIT ARE TO BE HELD TIGHT TO THE DECK. PLEASE CONSULT WITH THE CHIPOTLE CM SHOULD ANY CONFLICTS ARISE.
- BATT INSULATION TO BE INSTALLED ABOVE THE RESTROOM CEILING.
- ALL LAY-IN CEILING PENETRATIONS TO BE HELD TIGHT TO WALLS. REFER TO DETAIL ON SHEET A210 AND PLUMBING DRAWINGS FOR DETAILS.
- REFER TO STRUCTURAL DRAWINGS FOR HOOD SUSPENSION DETAILS.
- ALL EXTERIOR BUILDING MOUNTED AND PATIO LIGHT FIXTURES AND LAMPS PROVIDED BY TENANT'S LIGHT/LAMP SUPPLIER, U.N.O.
- ALL EXTERIOR PARKING LOT LIGHT FIXTURES AND LAMPS PROVIDED BY AND INSTALLED BY G.C. CAREFULLY REVIEW LIGHTING FIXTURE SCHEDULE ON SHEET E100.
- ALL EXTERIOR BUILDING MOUNTED AND PATIO LIGHT FIXTURES AND LAMPS INSTALLED BY G.C. CAREFULLY REVIEW LIGHTING FIXTURE SCHEDULE ON SHEET E100.
- SECURITY CAMERA LOCATIONS ARE ONLY APPROXIMATE LOCATIONS. FOR GUIDANCE ON THE SPECIFIC LOCATION/ORIENTATION OF THESE CAMERAS, REFER TO THE ENVISION INSTALLATION GUIDE
- REFER TO A120 FOR FINISH LEGEND.

KEYNOTE LEGEND

- INTERIOR SECURITY CAMERA LOCATIONS - TYPICAL SIX (6) - CENTER IN CEILING TILE WHERE APPLICABLE.
- LIGHTING FOR COOLER PROVIDED BY COOLER MANUFACTURER - GENERAL CONTRACTOR TO PROVIDE ROUGH-IN AND FINAL HOOK-UP.
- LINE OF SUSPENDED MENU BOARD SYSTEM.
- UNDERSHELF TASK LIGHTING - REFER TO ELECTRICAL SHEETS FOR ADDITIONAL INFORMATION.
- EXTERIOR SECURITY CAMERA LOCATIONS - TYPICAL OF TWO (2).
- LOCATION OF CEILING MOUNTED VESTIBULE HEATER - REFER TO ELECTRICAL DRAWINGS FOR ADDITIONAL INFORMATION.
- PROVIDE FREE AND CLEAR ACCESS TO HOOD AS REQUIRED - GENERAL CONTRACTOR TO COORDINATE WITH ALL TRADES TO MAINTAIN.
- LOCATION OF MONITOR BY TENANTS VENDOR.
- HOLD SOFFIT FRAMING SO GYPSUM SOFFIT FINISH DOESN'T OVERLAP WALL FINISH ON BOX BELOW - REFER TO FINISH PLAN FOR ADDITIONAL INFORMATION.
- MOUNT EMERGENCY LIGHT FIXTURE TO BOTTOM OF CANOPY.
- 4" PVC PIPES STUBBED ABOVE CEILING FOR SODA BUNDLE - REFER TO PLUMBING DRAWINGS FOR ADDITIONAL INFORMATION.
- AIR CURTIAN - REFER TO ELECTRICAL FOR ADDITIONAL INFORMATION
- CHIME/STROBE - REFER TO ELECTRICAL SHEETS FOR ADDITIONAL INFORMATION.
- ANSUL PULL TO BE LOCATED 48" A.F.F. TO THE CENTER OF UNIT ABOVE THE TIMECLOCK LOCATION.
- REFER TO MECHANICAL DRAWINGS FOR ALL FINAL DUCTWORK LOCATIONS.
- CENTER LIGHT FIXTURES BETWEEN STRUCTURAL MEMBERS.

CONDUIT GUIDELINES

SEE ELECTRICAL DRAWINGS FOR CONDUIT REQUIREMENTS. METAL CLAD CABLE AND FLEXIBLE METAL CONDUIT SHALL NOT BE INSTALLED IN AREAS EXPOSED TO VIEW UNLESS SPECIFICALLY NOTED OTHERWISE

SECURITY DEVICE SCHEDULE

DESCRIPTION	QTY	FURNISHED BY	INSTALLED BY	UTILITIES			REMARKS
				ELEC	GAS	SEWER	
SECURITY MONITOR	1	SSS	SSS	•			
SECURITY ALARM - MOTION DETECTORS	1	T.B.D.	T.B.D.	•			GC RESPONSIBLE FOR COORDINATING SEQUENCING OF PREWIRING WITH COMPLETION OF INTERIOR FINISHES (GYP. BD. FINISHES)
72 HR SECURITY DVR	1	SSS	SSS	•			
CLOSED CIRCUIT T.V. CAMERA - OUTDOOR	2	SSS	SSS	•			INSTALL AT 9'-6" U.N.O.
CLOSED CIRCUIT T.V. CAMERA - INDOOR	6	SSS	SSS	•			

SPEAKER SCHEDULE

ITEM #	QTY	DESCRIPTION	COLOR/FINISH	MOUNT	REMARKS
SP1	4	DINING ROOM SPEAKER	BLACK	SUSPENDED	REFER TO A201 & E110 FOR DETAILS

CONSULTANT:



CLIENT:



CHIPOTLE MEXICAN GRILL, INC.
P.O. BOX 182666
COLUMBUS, OH 43218-2666
TELEPHONE: (614) 318-2482
INTERNET: WWW.CHIPOTLE.COM


COPYRIGHT 2024
THIS DRAWING IS AN INSTRUMENT OF SERVICE AND AS SUCH REMAINS THE PROPERTY OF CHIPOTLE MEXICAN GRILL, INC. PERMISSION FOR USE OF THIS DOCUMENT IS LIMITED AND CAN BE EXTENDED ONLY BY WRITTEN AGREEMENT WITH CHIPOTLE MEXICAN GRILL, INC.

PROJECT INFORMATION:

STORE NO.: 5037

HUNTLEY
12990 ROUTE 47, LOT 4B
HUNTLEY, IL 60142

SEAL:

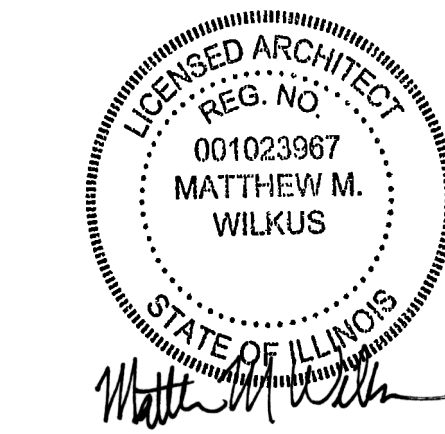

May 06, 2024

MATTHEW M. WILKUS
LICENSE #001.023967
(EXPIRES 11/30/2024)

PROJECT NO. 2023-0175
DRAWN BY JSB, DVA
CHECKED BY DVA, NSG, KAM, MMW

ISSUE RECORD:
02/12/2024 PERMIT SUBMITTAL
03/15/2024 BID SET
05/03/2024 CONSTRUCTION SET














REVISIONS:

TITLE:

REFLECTED
CEILING PLAN

SHEET NUMBER:

A201

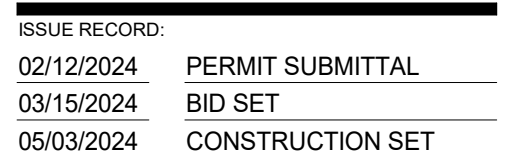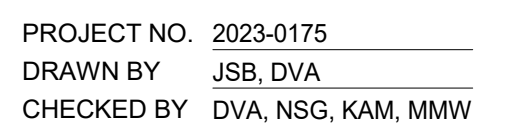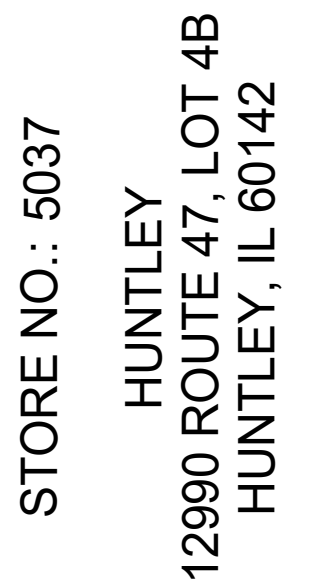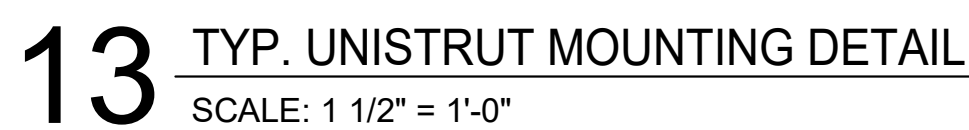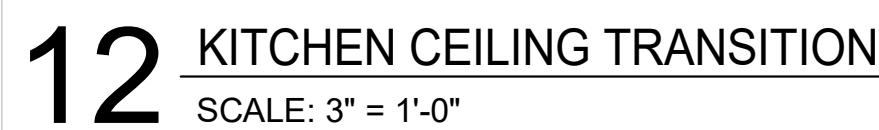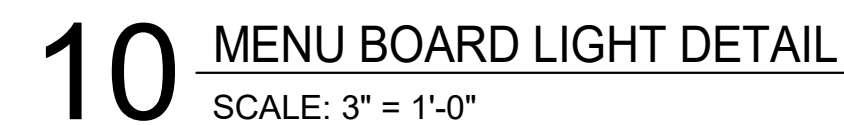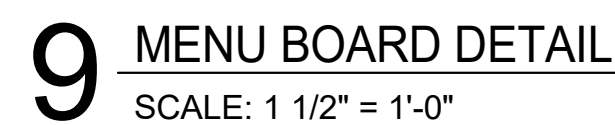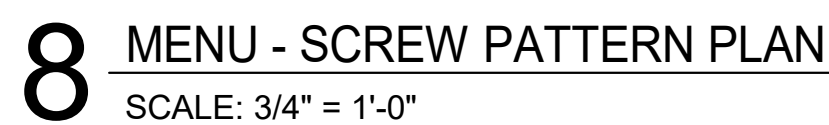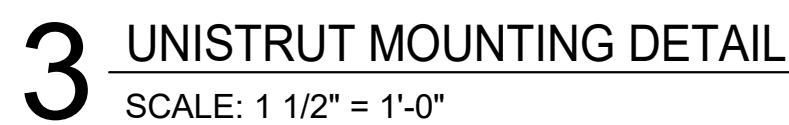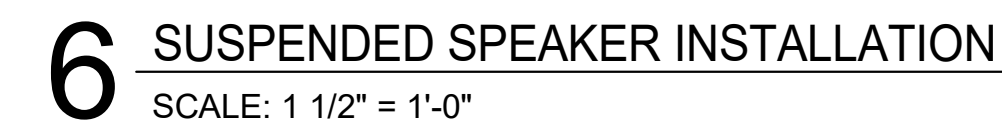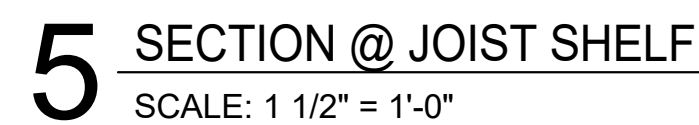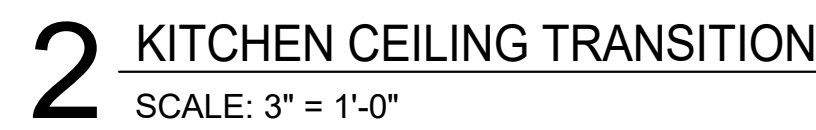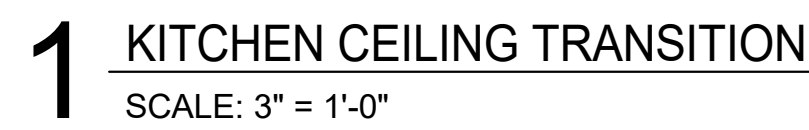


REVISIONS: _____

TITLE:


CEILING DETAILS

SHEET NUMBER: _____


A210

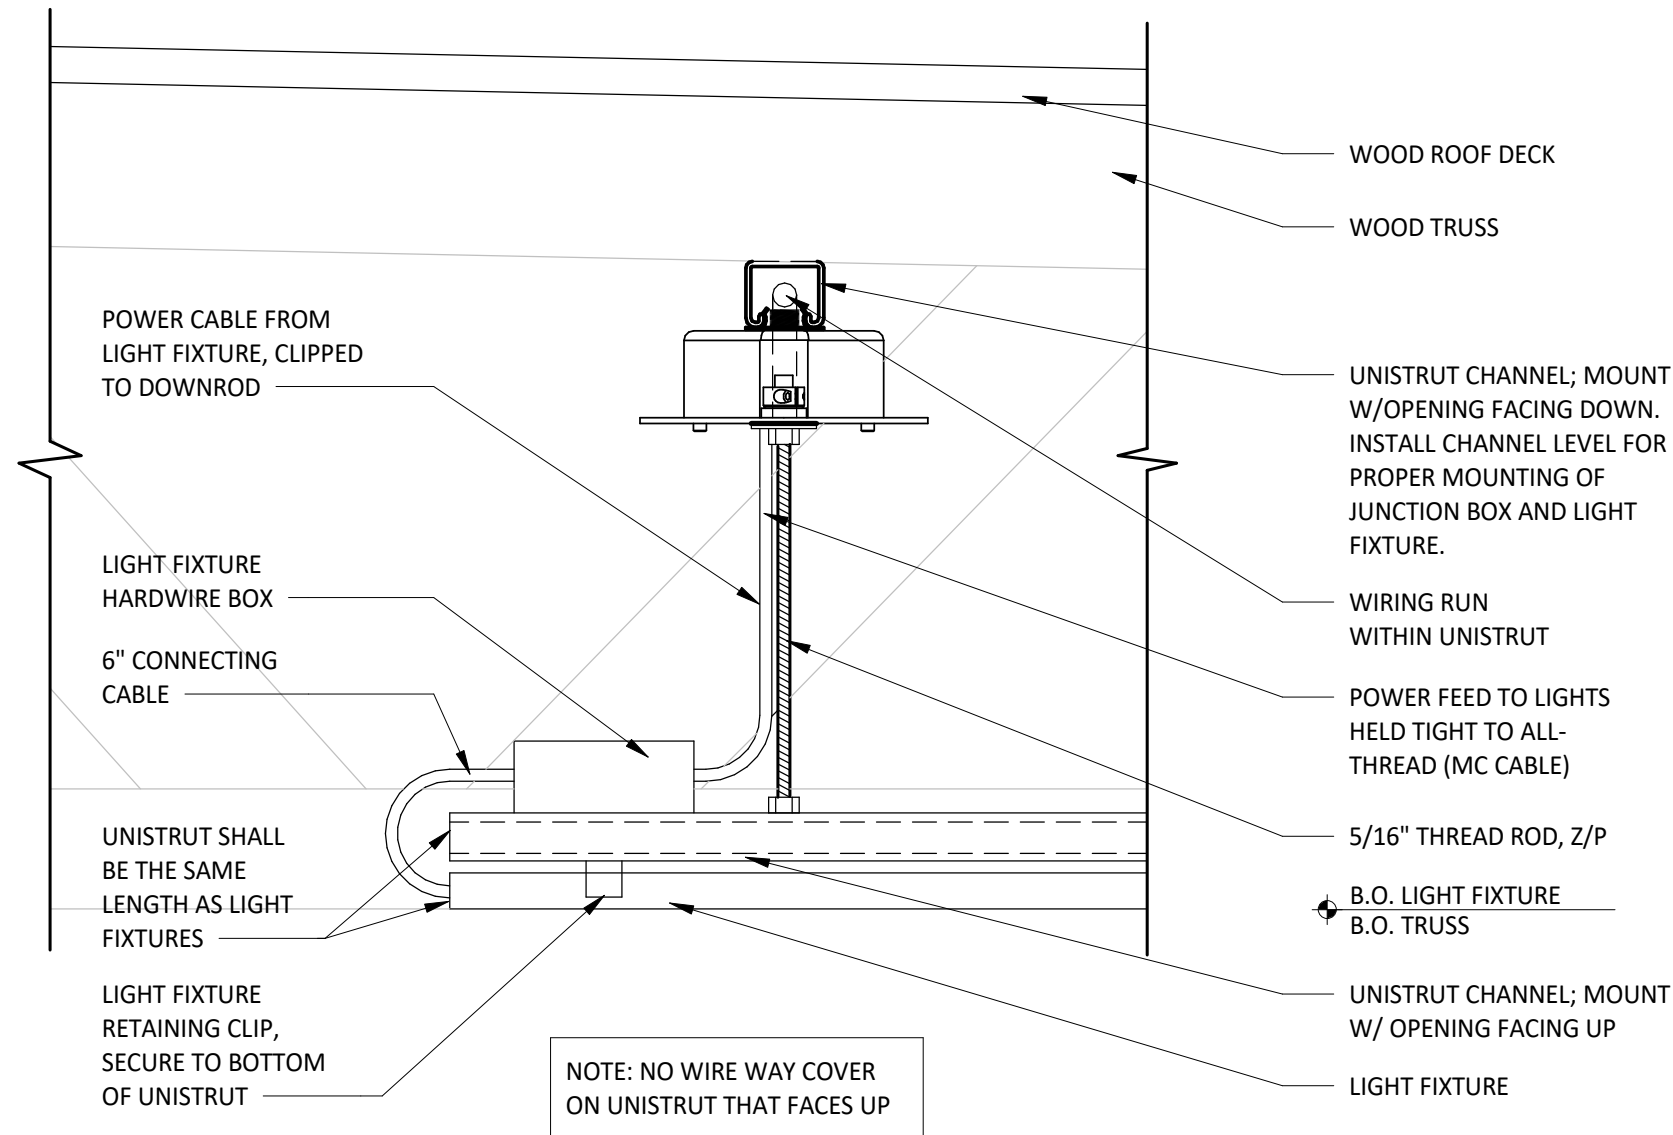


1 SUSPENDED STRIP LIGHT CONNECTION DETAIL
SCALE: 3" = 1'-0"

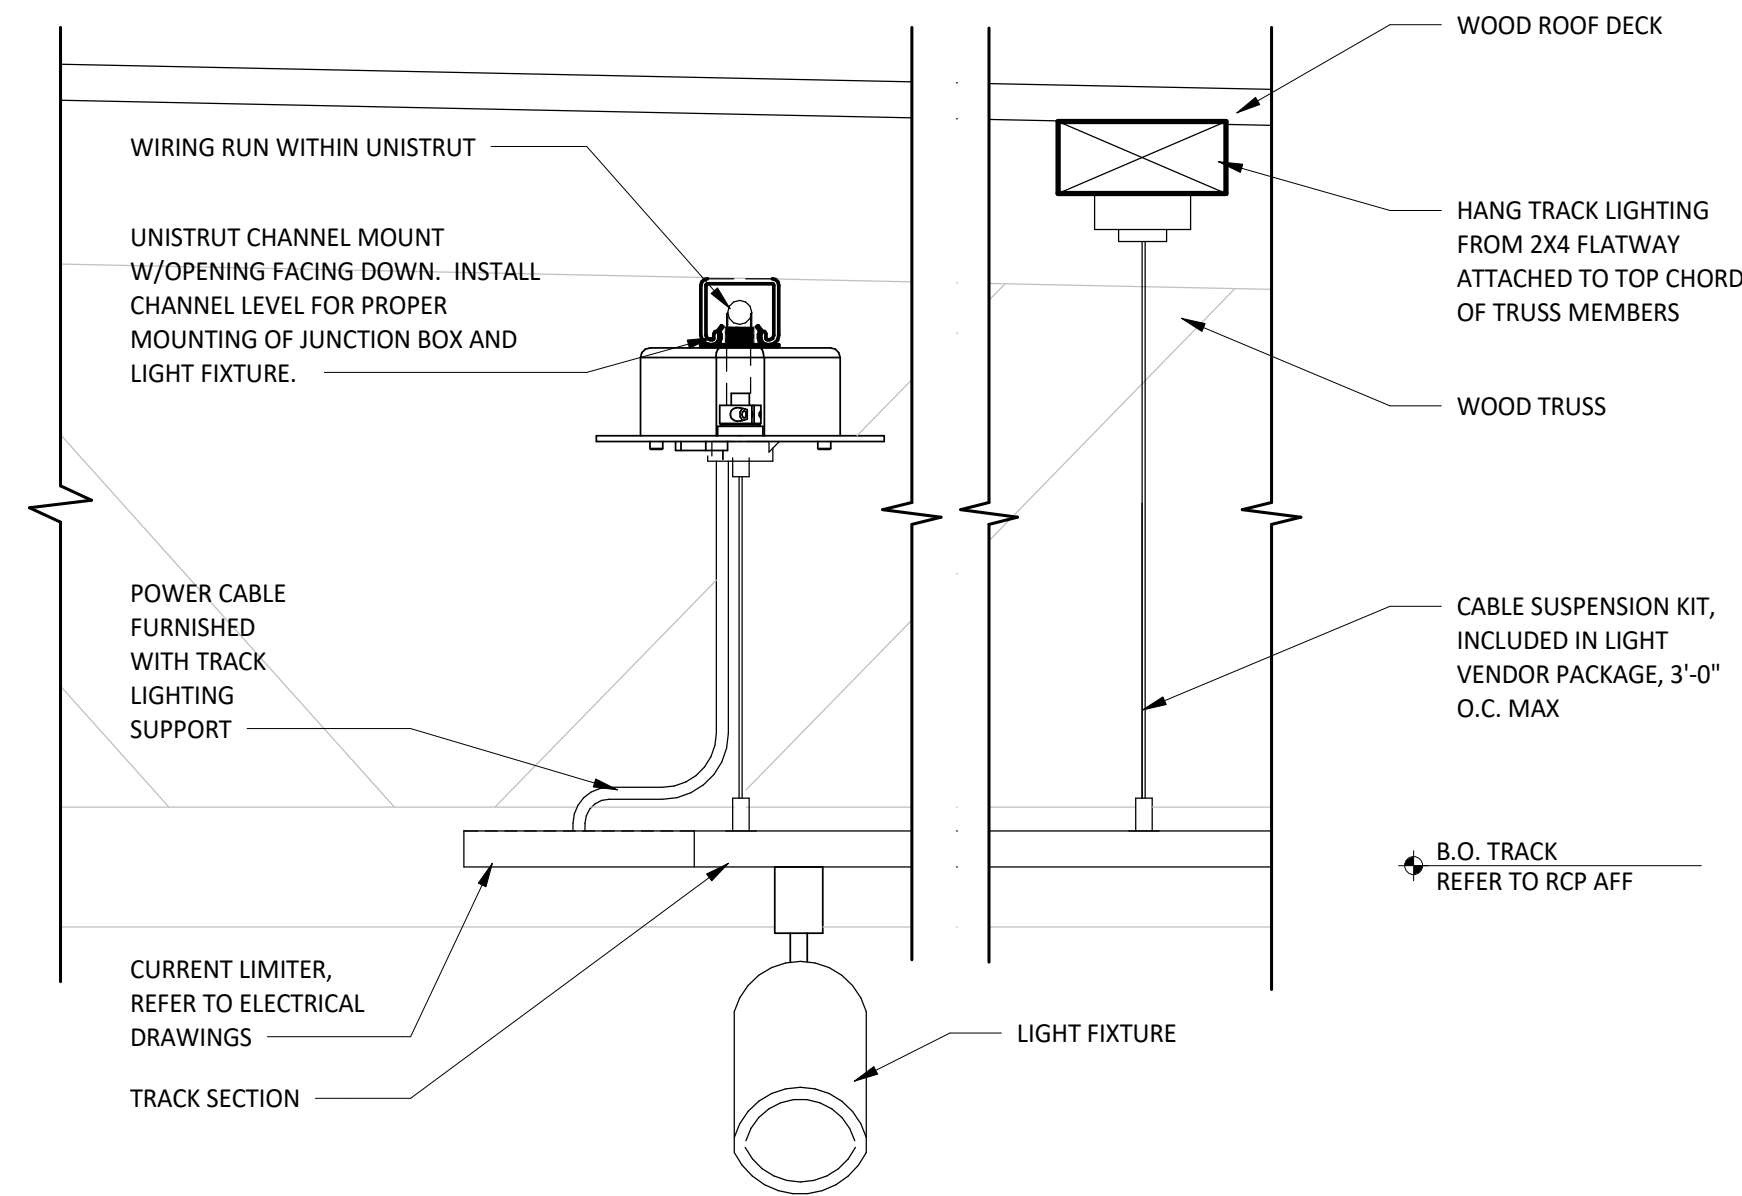

2 SUSPENDED TRACK LIGHT CONNECTION DETAIL
SCALE: 3" = 1'-0"

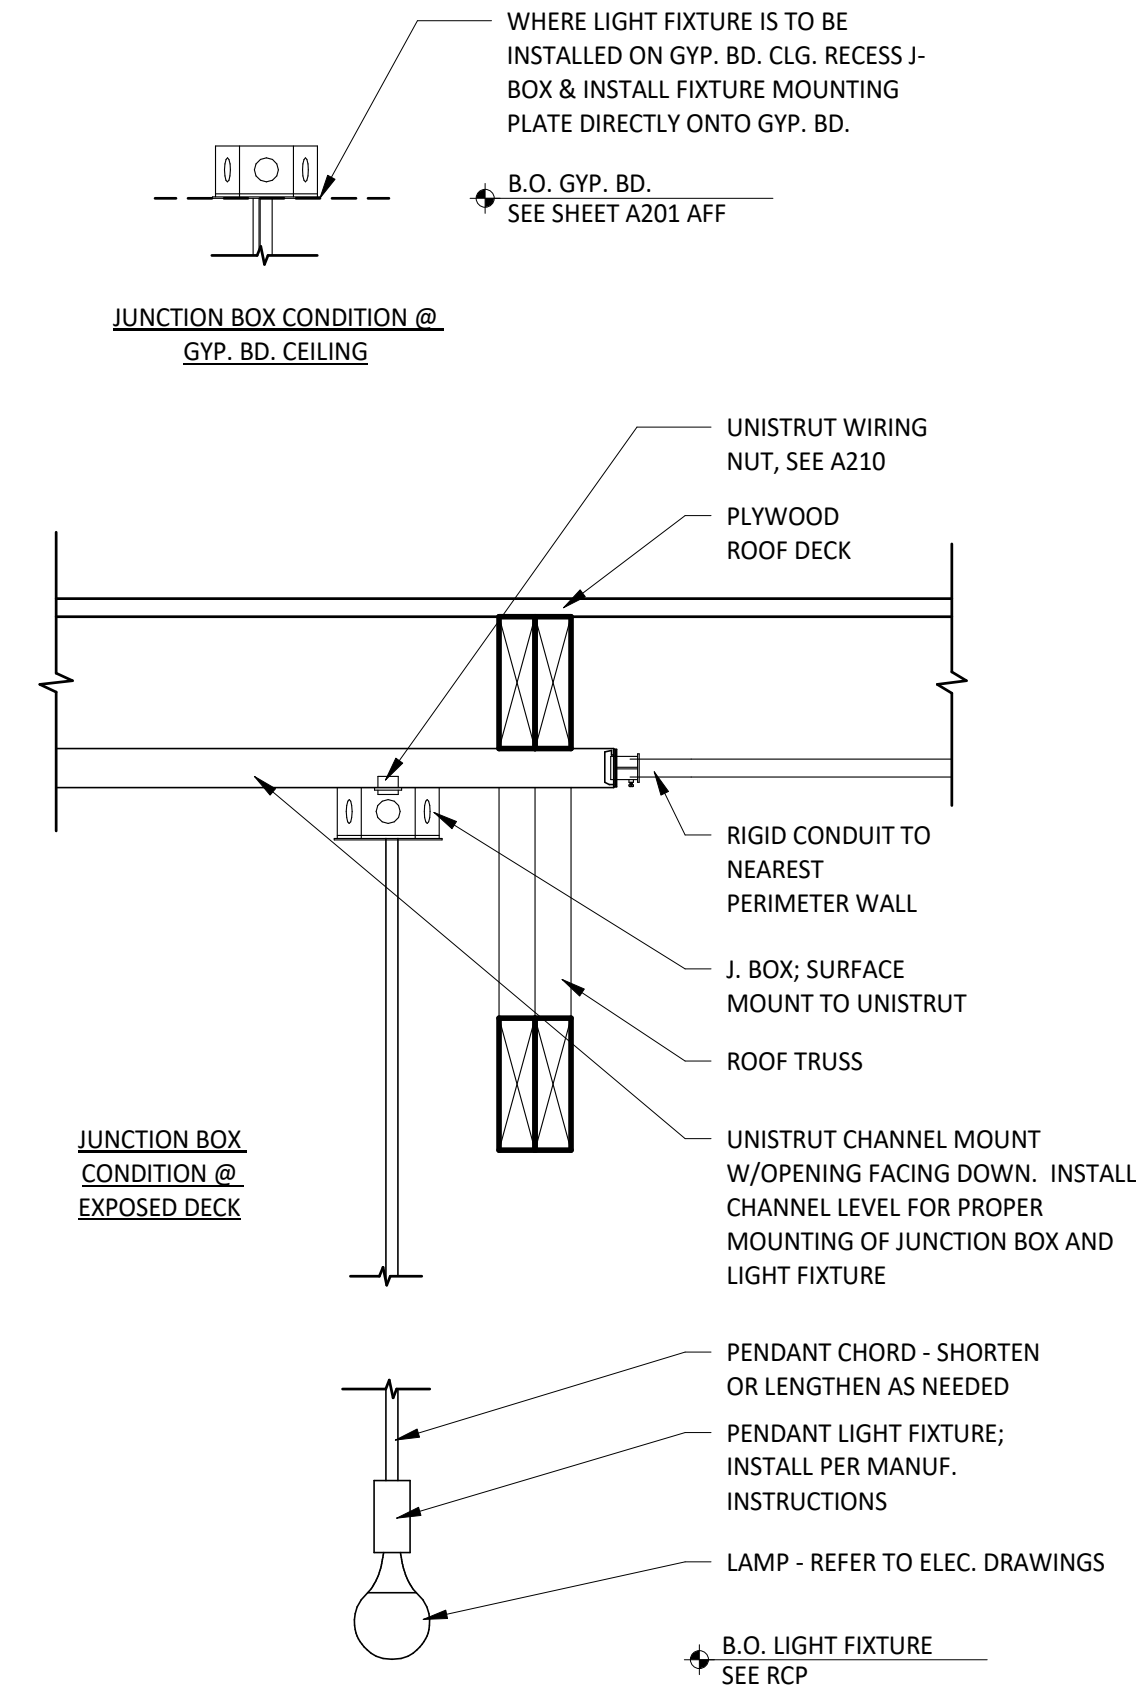

3 PENDANT LIGHT FIXTURE
SCALE: 1 1/2" = 1'-0"

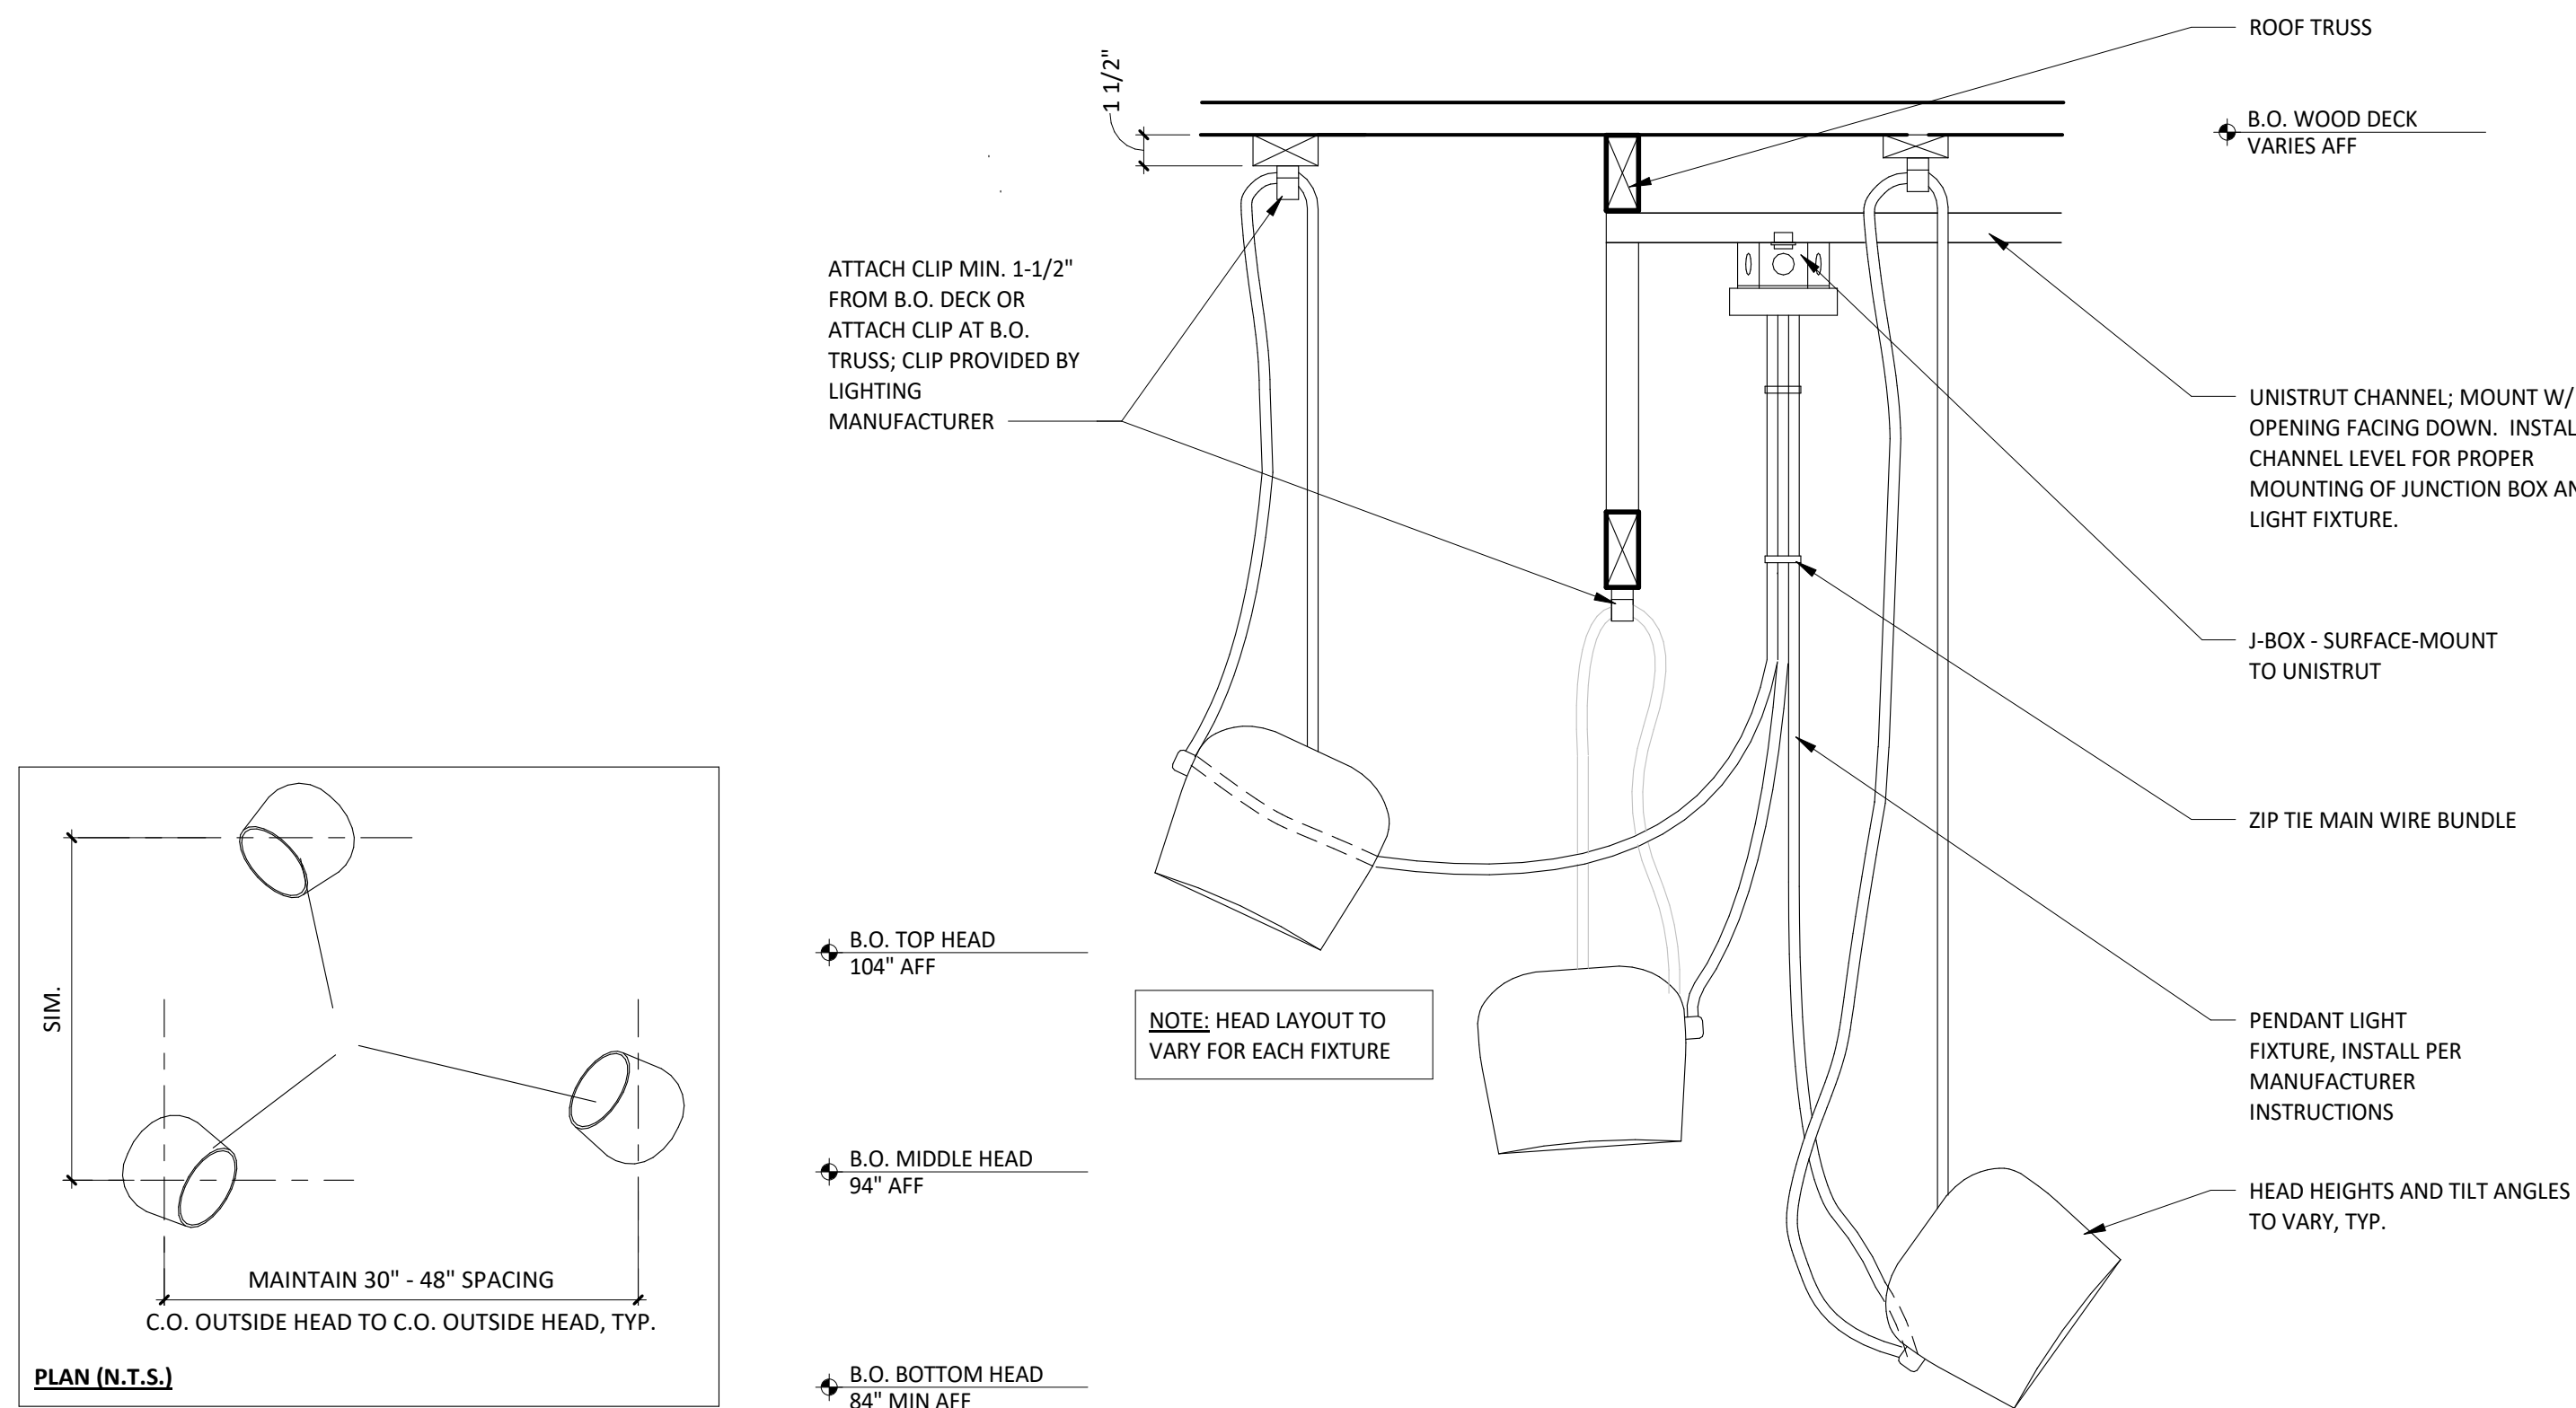


4 PENDANT LIGHT
SCALE: 1 1/2" = 1'-0"



COPYRIGHT 2024
THIS DRAWING IS AN INSTRUMENT OF SERVICE AND AS SUCH REMAINS THE PROPERTY OF CHIPOTLE MEXICAN GRILL, INC. PERMISSION FOR USE OF THIS DOCUMENT IS LIMITED AND CAN BE EXTENDED ONLY BY WRITTEN AGREEMENT WITH CHIPOTLE MEXICAN GRILL, INC.
PROJECT INFORMATION:

STORE NO.: 5037
HUNTLEY
12990 ROUTE 47, LOT 4B
HUNTLEY, IL 60142

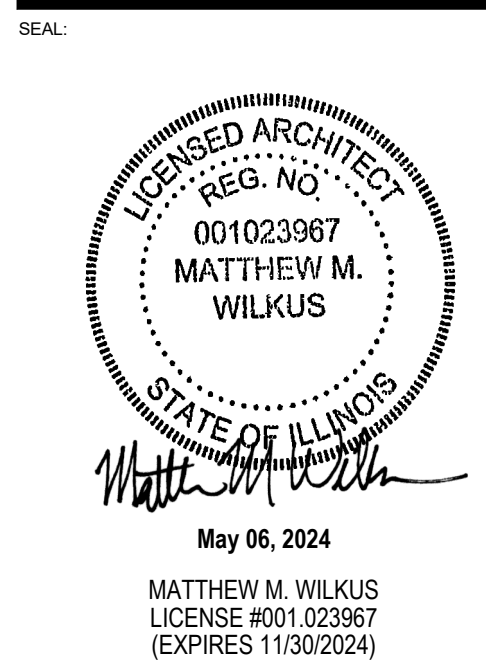


PROJECT NO. 2023-0175
DRAWN BY JSB, DVA
CHECKED BY DVA, NSG, KAM, MMW

ISSUE RECORD:
02/12/2024 PERMIT SUBMITTAL
03/15/2024 BID SET
05/03/2024 CONSTRUCTION SET


REVISIONS:	

TITLE:
LIGHTING DETAILS

SHEET NUMBER:
A211

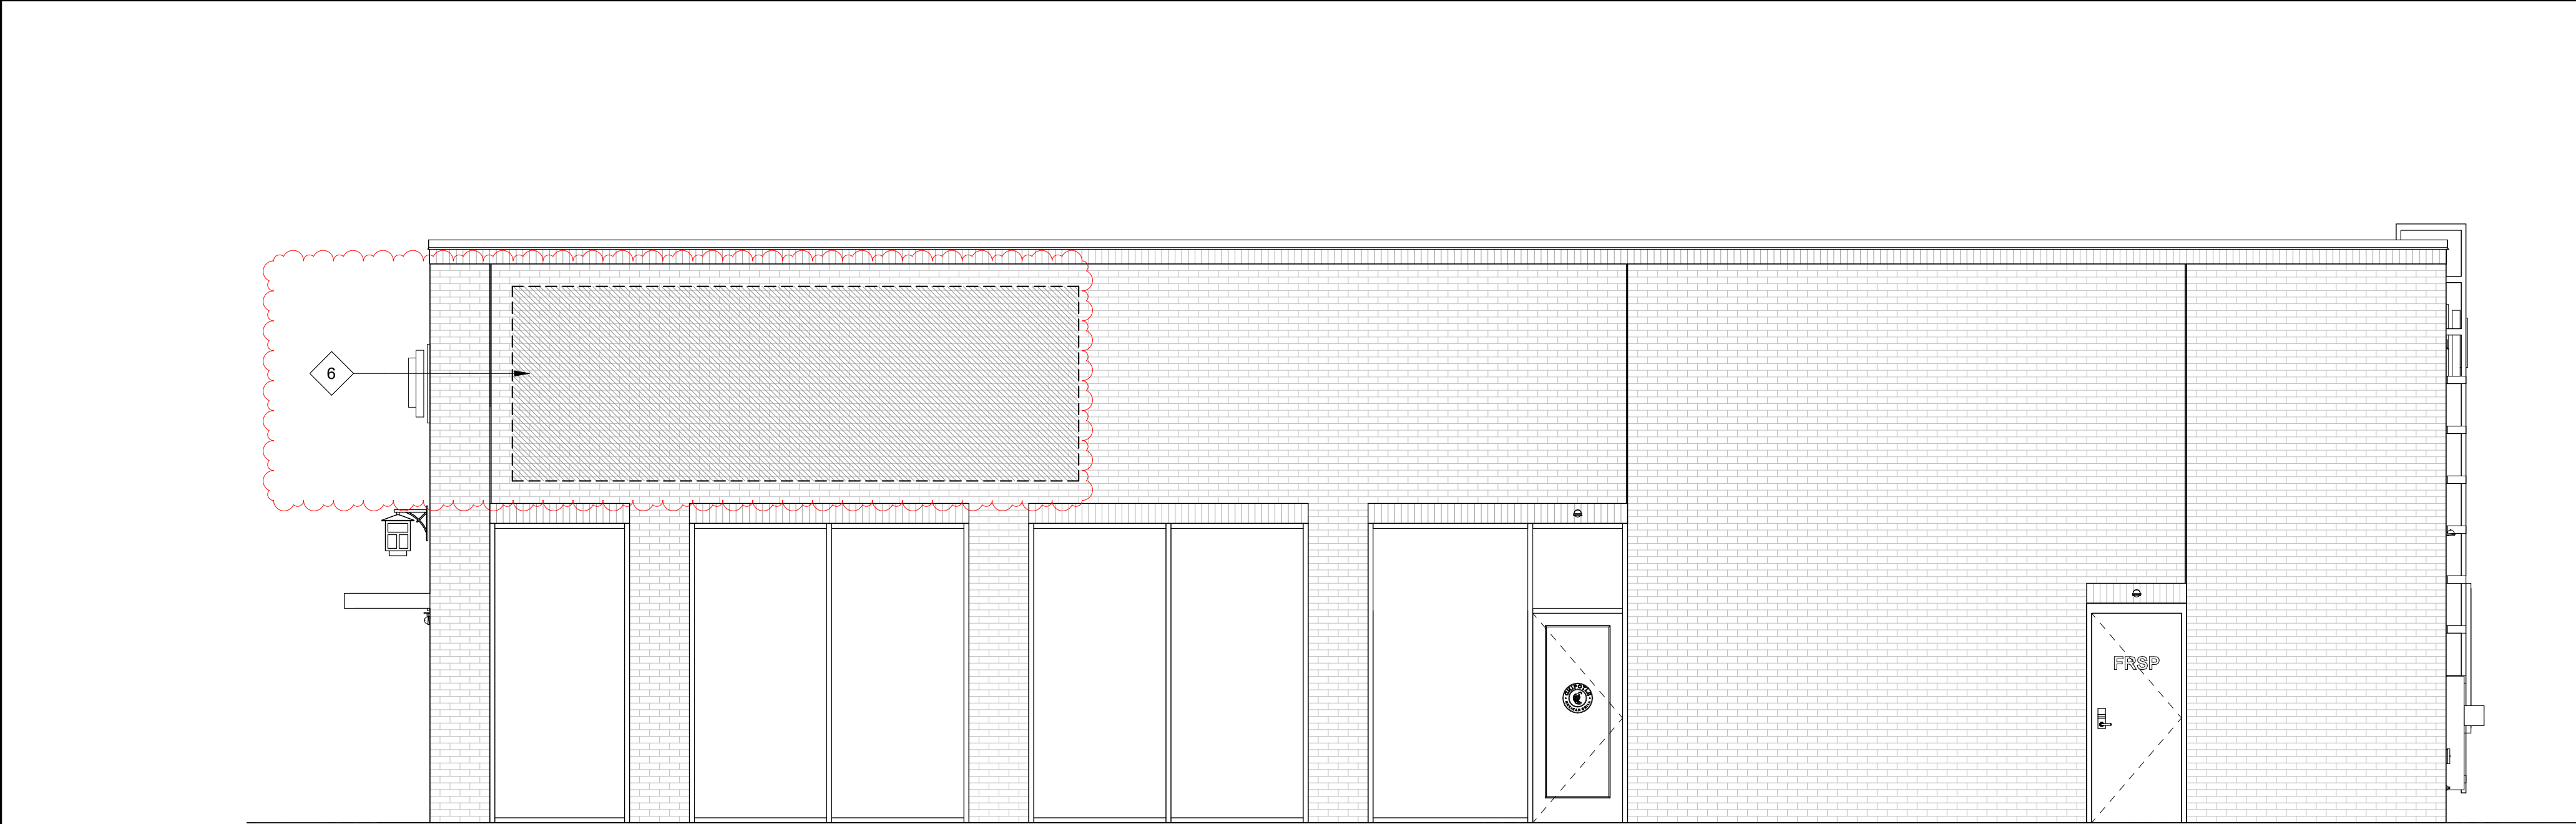


1 EXTERIOR ELEVATION
SCALE: 1/4" = 1'-0"

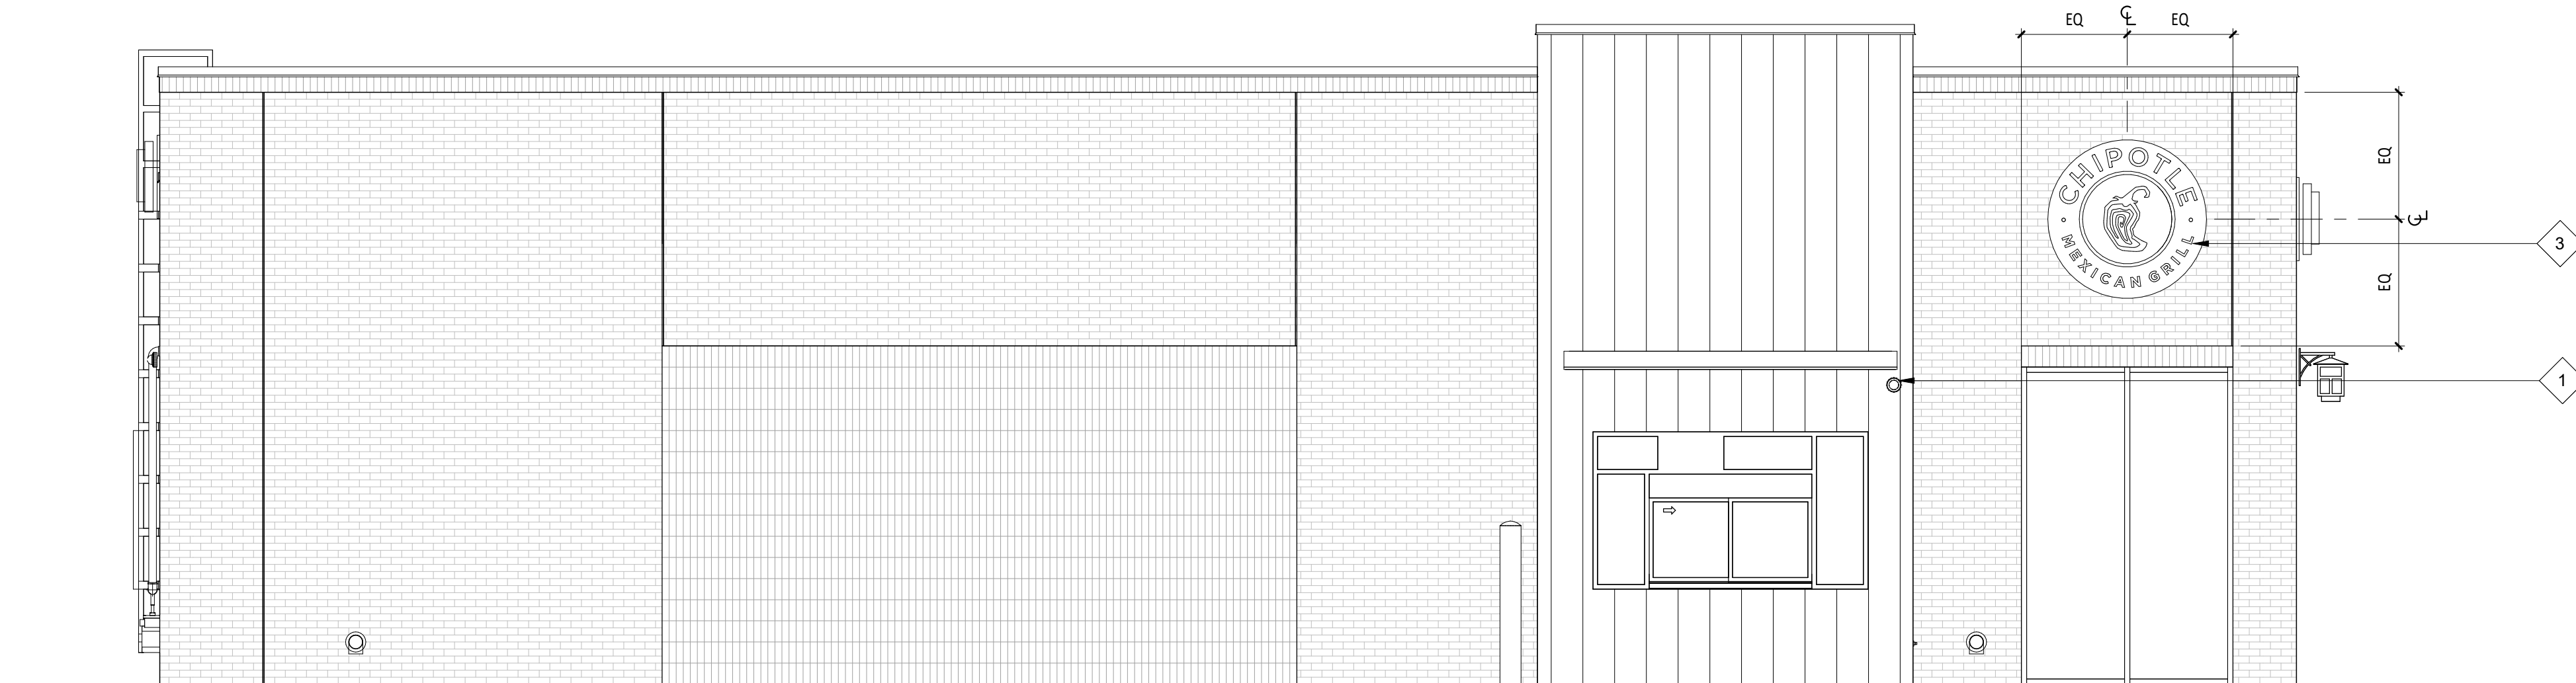

2 EXTERIOR ELEVATION
SCALE: 1/4" = 1'-0"



3 EXTERIOR ELEVATION
SCALE: 1/4" = 1'-0"

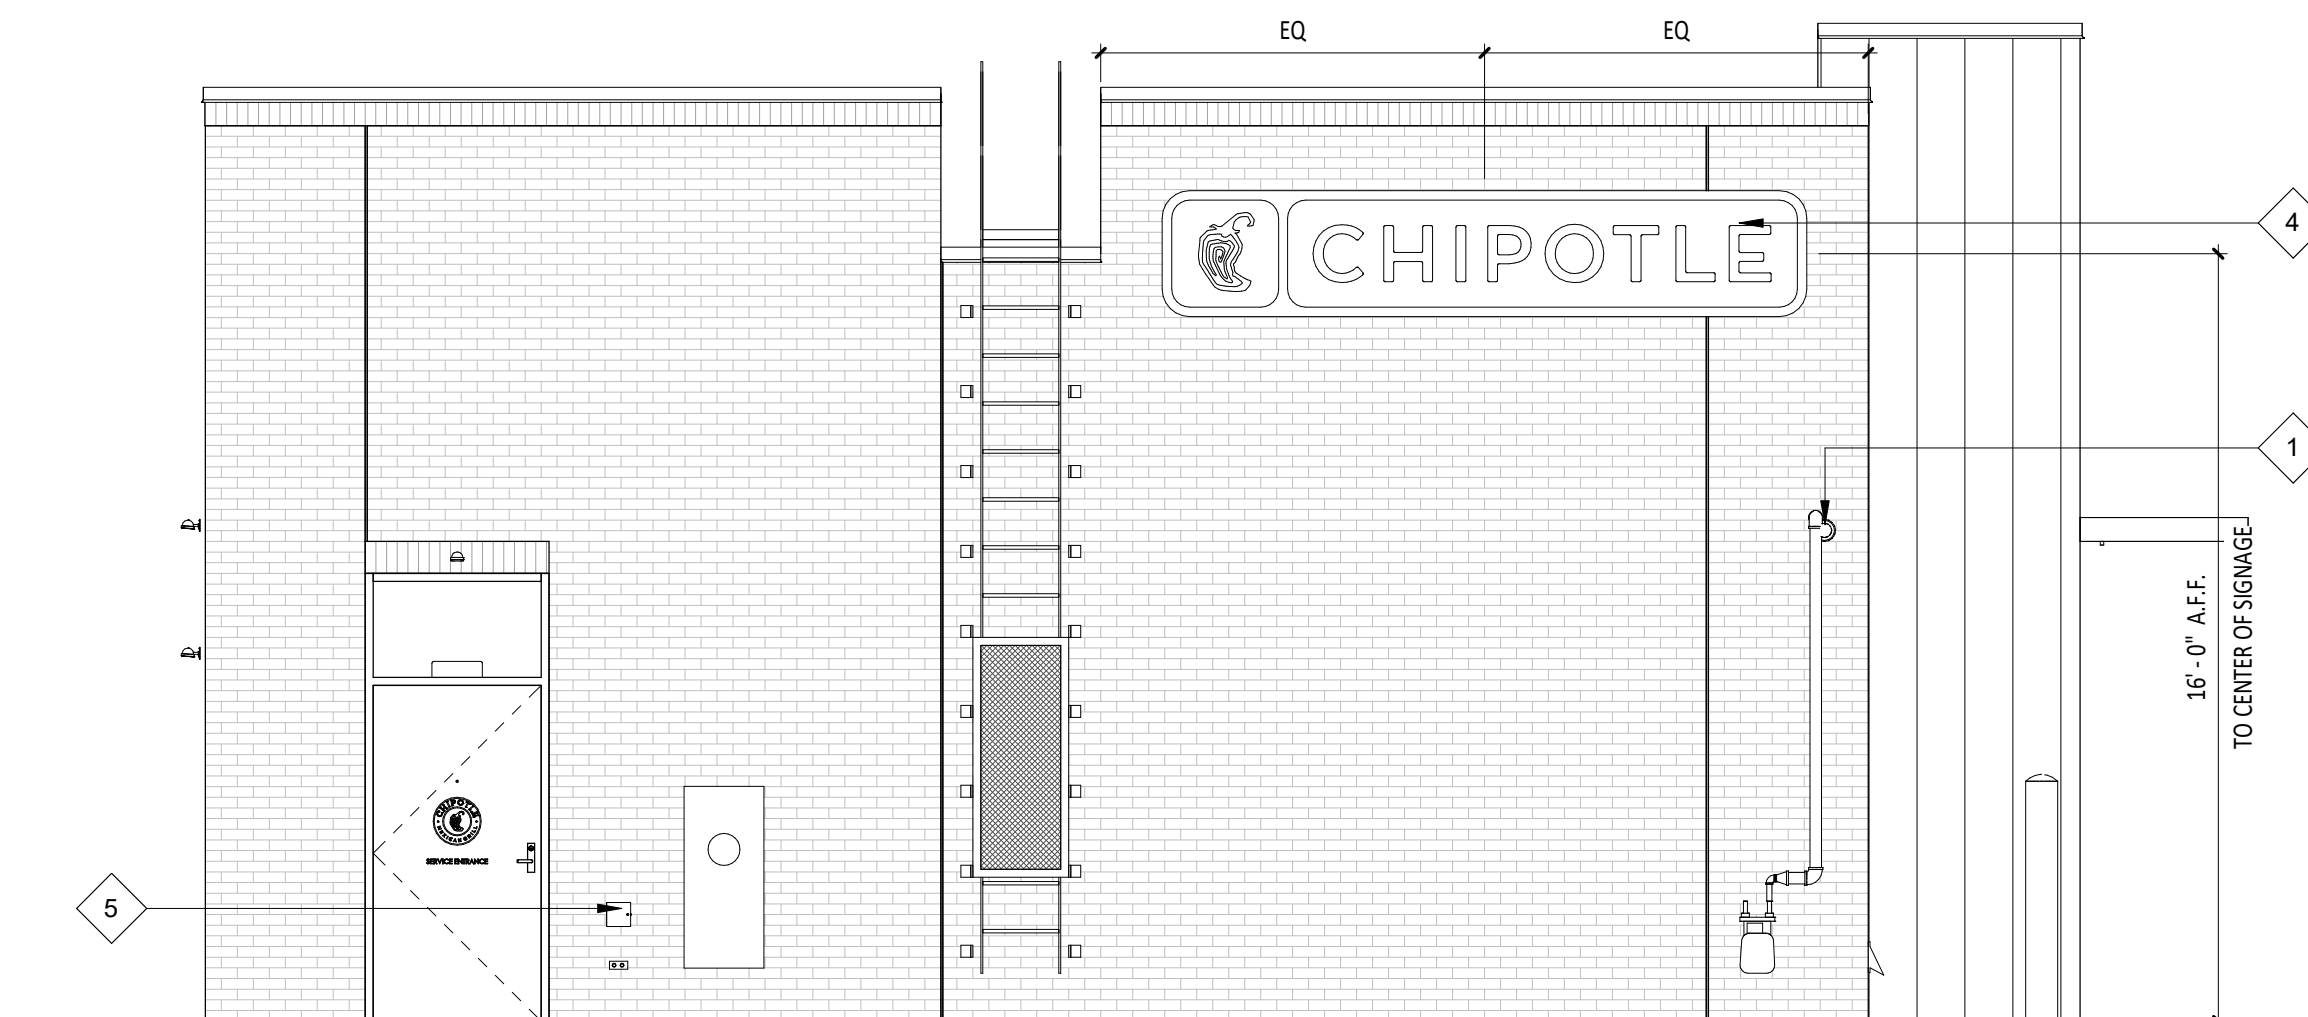

4 EXTERIOR ELEVATION
SCALE: 1/4" = 1'-0"

GENERAL NOTES - EXT. ELEV.

- A. SIGNAGE IS SHOWN ONLY FOR PLACEMENT AND SCALE. ALL SIGNAGE FOR REVIEW UNDER SEPARATE PERMIT, NOT PART OF THIS PERMIT SET.
B. EXTERIOR SIGNAGE PROVIDED BY TSV AND INSTALLED BY TSV. GC TO MAKE FINAL CONNECTION.

KEYNOTE LEGEND

- 1 LOCATION OF SECURITY CAMERAS TO BE INSTALLED BY GENERAL CONTRACTOR.
- 2 6" VINYL ADDRESS LETTERS - COORDINATE ADOPTED REQUIREMENTS ON SIZE AND LOCATION WITH LOCAL JURISDICTION.
- 3 LOCATION OF TENANT'S CUSTOM MEDALLION SIGNAGE - GENERAL CONTRACTOR TO COORDINATE BLOCKING REQUIREMENTS WITH SIGNAGE VENDOR.
- 4 LOCATION OF TENANTS BW-3 SIGNAGE - GENERAL CONTRACTOR TO COORDINATE BLOCKING REQUIREMENTS WITH SIGNAGE VENDOR.
- 5 LOCATION OF REMOTE CO2 FILLER - INSTALL BETWEEN 36" AND 48" ABOVE FINISHED GRADE - VERIFY LOCATION WITH CHIPOTLE CONSTRUCTION MANAGER.
- 6 LOCATION OF TENANTS FUTURE SIGNAGE - GENERAL CONTRACTOR TO COORDINATE BLOCKING REQUIREMENTS WITH SIGNAGE VENDOR.



CLIENT:




COPYRIGHT 2024
THIS DRAWING IS AN INSTRUMENT OF SERVICE AND AS SUCH REMAINS THE PROPERTY OF CHIPOTLE MEXICAN GRILL, INC. PERMISSION FOR USE OF THIS DOCUMENT IS LIMITED AND CAN BE EXTENDED ONLY BY WRITTEN AGREEMENT WITH CHIPOTLE MEXICAN GRILL, INC.

PROJECT INFORMATION:

STORE NO.: 5037
HUNTLEY
12990 ROUTE 47, LOT 4B
HUNTLEY, IL 60142

SEAL:

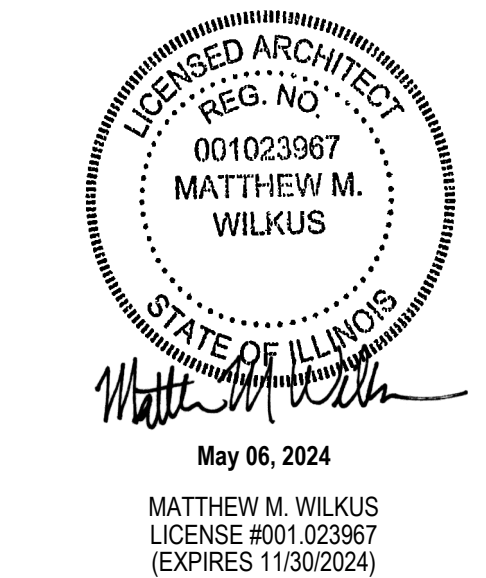

PROJECT NO. 2023-0175
DRAWN BY JSB, DVA
CHECKED BY DVA, NSG, KAM, MMW



ISSUE RECORD:
02/12/2024 PERMIT SUBMITTAL
03/15/2024 BID SET
05/03/2024 CONSTRUCTION SET

REVISIONS:
2 03.15.2024 CITY COMMENTS

TITLE:
EXTERIOR
ELEVATIONS

SHEET NUMBER:

A301

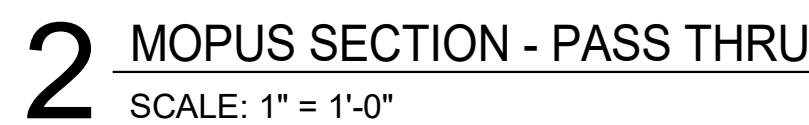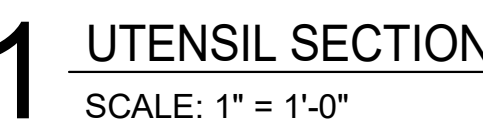


DOOR SCHEDULE

TAG	ROOM	DOOR STATUS *	FRAME STATUS	DOOR DESCRIPTION	DOOR WIDTH	DOOR HEIGHT	DOOR THICKNESS	DOOR TYPE	DOOR FINISH	FRAME	FRAME TYPE	MATERIAL	STILE	HARDWARE SET	HARDWARE STATUS*	FIRE RATING	REMARKS
1	MAIN ENTRY	EXISTING	EXISTING	DOUBLE STOREFRONT (WIDE STILE, WOOD PULL/PUSH)	6' - 0"	7' - 0"	0' - 1 3/4"	A	CHARCOAL	STOREFRONT	ALUM	WIDE (5")	1	EXISTING	-	1,2,4	
2	PASSAGE	EXISTING	EXISTING	SINGLE STOREFRONT (WIDE STILE, NON-OFFSET, PANIC)	3' - 0"	7' - 0"	0' - 1 3/4"	A	CHARCOAL	STOREFRONT	ALUM	WIDE (5")	2	EXISTING	-	1,2,3,4	
3	FIRE SPRINK ROOM	EXISTING	EXISTING	HM FIRE ROOM (MASONRY)	3' - 0"	7' - 0"	0' - 1 3/4"	B	PAINT	2	INSUL. H.M.M.	-	3	EXISTING	-	1,3,5	
4	KITCHEN	EXISTING	EXISTING	HM REAR SERVICE (MASONRY)	3' - 6"	7' - 0"	0' - 1 3/4"	B	PAINT	2	INSUL. H.M.	-	3	EXISTING	-	1,3,5	
5	OFFICE	NEW	NEW	MANAGER'S OFFICE	3' - 0"	7' - 0"	0' - 1 3/4"	C	D1 (SEE A120)	1	H.M.	-	4	NEW	-		
6	TOILET ROOM 2	NEW	NEW	UNISEX 2 RESTROOM (SINGLE-OCCUPANT, STANDARD)	3' - 0"	7' - 0"	0' - 1 3/4"	B	D1 (SEE A120)	1	H.M.	-	5	NEW	-		
7	TOILET ROOM 1	NEW	NEW	UNISEX 1 RESTROOM (SINGLE-OCCUPANT, STANDARD)	3' - 0"	7' - 0"	0' - 1 3/4"	B	D1 (SEE A120)	1	H.M.	-	6	NEW	-		
8	MAIN ENTRY	NEW	NEW	SINGLE STOREFRONT - VESTIBULE (WIDE STILE, NON-OFFSET)	3' - 0"	7' - 0"	0' - 1 3/4"	A	SEE A301	STOREFRONT	ALUM	WIDE (5")	2D	NEW	-	5	
9	MAIN ENTRY	NEW	NEW	SINGLE STOREFRONT - VESTIBULE (WIDE STILE, NON-OFFSET)	3' - 0"	7' - 0"	0' - 1 3/4"	A	SEE A301	STOREFRONT	ALUM	WIDE (5")	2D	NEW	-	5	

DOOR REMARKS

- DOORS WITH REMARK #1 TO BE KEYED THE SAME
- EXIT INDICATOR ARRIVES WITH SIGNS STATING "THIS DOOR TO REMAIN UNLOCKED DURING BUSINESS HOURS" AND "THIS DOOR TO REMAIN UNLOCKED WHEN THE BUILDING IS OCCUPIED". VERIFY REQUIRED SIGN WORDING WITH LOCAL JURISDICTION PRIOR TO INSTALLATION. ONE SIGN IS TO BE PLACED IN A VISIBLE LOCATION ABOVE THE DOORS.
- THERE IS TO BE NO EXTERIOR HOLE OR CYLINDER
- USE NON-SHRINK STRUCTURAL GROUT BED UNDER THRESHOLD
- BLACK DOOR SWEEP TO BE USED WITH CHARCOAL STOREFRONT.
- IF STATUS IS "EXISTING" G.C. TO DETERMINE CONDITION OF EXISTING HARDWARE. IF HARDWARE IS IN POOR CONDITION, PROVIDE HARDWARE IN HARDWARE SCHEDULE. CONFIRM REPLACEMENT WITH CHIPOTLE CM.
- REAR KITCHEN DOOR TO BE PAINTED 'BLACK' ON INTERIOR AND 'KNIGHTS ARMOR' ON EXTERIOR U.N.O.

TYPICAL EXTERIOR DOOR TYPES

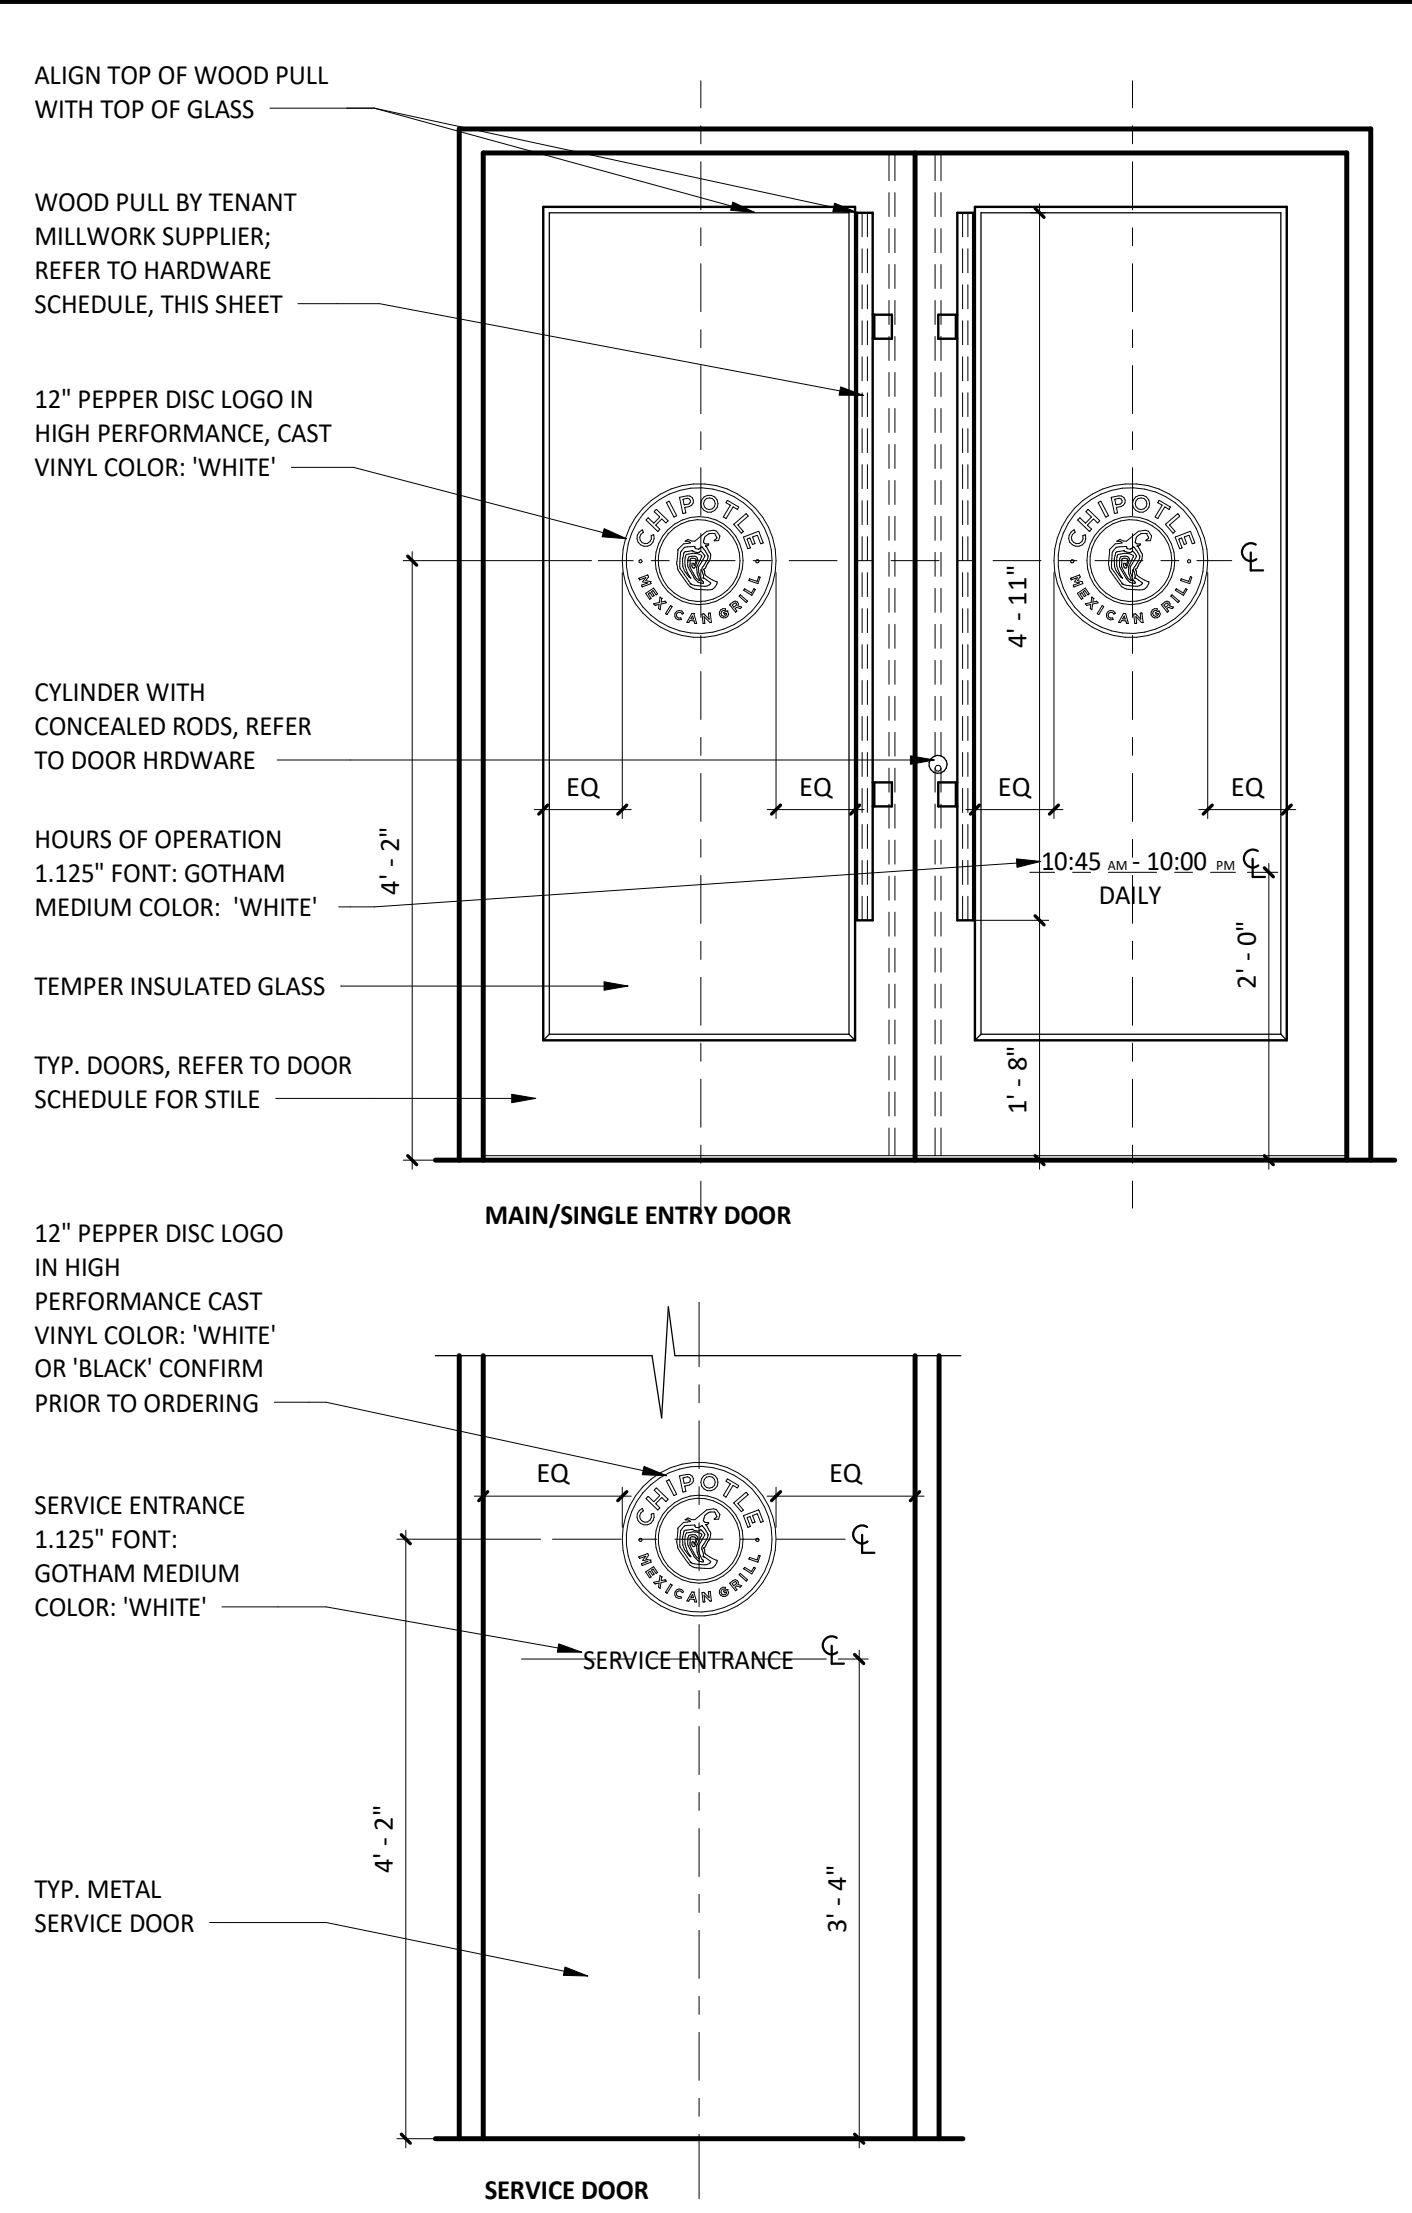

EXISTING HARDWARE SETS

G.C. TO CONFIRM ALL REQUIRED EXISTING HARDWARE IS PRESENT AND IS IN WORKING CONDITION. IF HARDWARE IS IN POOR CONDITION OR MISSING, PROVIDE HARDWARE IN HARDWARE SCHEDULE BELOW; CONFIRM REPLACEMENT WITH CHIPOTLE CM.

SET 1 - MAIN ENTRY - PAIR - WOOD PULL/PUSH

- (2) HINGE HAGER, MODEL 780-224HD-83"-CLR
- (2) MORTISE CYLINDER SCHLAGE, MODEL 80-103, BRUSHED CHROME; C.O. CYLINDER AT 34" MIN. FROM BOTTOM OF DOOR
- (2) TEMP CORE SCHLAGE, MODEL 80-035 INTERCHANGEABLE CORE, (BRUSHED CHROME)
- (1) DEADBOLT ADAMS RITE, MODEL M518505-310-628
- (1) EXIT INDICATOR ADAMS RITE, MODEL 4089-00-130
- (1) HEADER BOLT ADAMS RITE, MODEL 4016-30-01
- (1) THRESHOLD BOLT ADAMS RITE, MODEL 4015-18-1B
- (2) CLOSER DORMA, MODEL 8916-AF89P (TOP JAMB), (ALUMINUM)
- (2) DOOR STOP IVES, MODEL FS18S (ALUMINUM)
- (2) OVERHEAD STOP GLYNN-JOHNSON, MODEL 454S-SP28 (ALUMINUM)
- (2) CLOSER BACK PLATE DORMA, MODEL BP89, ALUMINUM
- (1) THRESHOLD PEMKO, MODEL S239A-72 (SIZE 72")
- (2) SMOKE SEAL REESE, MODEL 797B-21
- (2) DOOR SWEEP PEMKO, MODEL SFS-200-36 (36" DOOR), OWNER FURNISHED

SET 2 - EGRESS ONLY - SINGLE - NON-OFFSET - PANIC HARDWARE

- (1) HINGE HAGER, MODEL 780-224HD-83"-CLR
- (1) PUSH HARDWARE ADAMS RITE, MODEL 8801-36-628 (ALUMINUM FINISH, 36" DOOR); C.O. EXIT DEVICE AT 38" FROM BOTTOM OF DOOR
- (1) CLOSER DORMA, MODEL 8916-AF89P-689 (TOP JAMB), (ALUMINUM)
- (1) CLOSER BACK PLATE DORMA, MODEL BP89, ALUMINUM
- (1) OVERHEAD STOP GLYNN-JOHNSON, MODEL 454S-US32D (ALUMINUM)
- (1) THRESHOLD REESE, MODEL S424A-36 (SIZE 36")
- (1) SMOKE SEAL REESE, MODEL 797B-21
- (1) DOOR SWEEP PEMKO, MODEL SFS-200-36 (36" DOOR), OWNER FURNISHED
- (1) DOOR STOP IVES, MODEL FS18S (ALUMINUM)

SET 3 - REAR EXIT - SINGLE

- (1) HINGE HAGER, MODEL 780-224HD-83"-CLR
- (1) PUSH HARDWARE FALCON, MODEL 25-R-EO-4"-US28 (SIZE 42")
- (1) PULL HARDWARE FALCON, MODEL 510L-DANE-LHR-US26D, ALUMINUM (EXTERIOR SIDE)
- (1) RIM CYLINDER GLS, MODEL RCIC-7-LZ-626
- (1) TEMP CORE SCHLAGE, MODEL 80-035 INTERCHANGEABLE CORE (FINISH: BRUSHED CHROME)
- (1) CLOSER DORMA, MODEL 8916-AF89P-689 (TOP JAMB), ALUMINUM
- (1) CLOSER BACK PLATE DORMA, MODEL BP89, ALUMINUM
- (1) THRESHOLD REESE, MODEL S239A-42, (SIZE 42")
- (1) WEATHERSTRIP REESE, MODEL OS75C-4070
- (1) DOOR SWEEP PEMKO, MODEL SFS-200-42 (42" DOOR) (BLACK) OWNER FURNISHED
- (1) DOOR VIEWER IVES, MODEL U688B26D, C.O. VIEWER AT 60" FROM BOTTOM OF DOOR
- (1) DOOR SILENCERS IVES, MODEL SR64
- (1) DOOR BUZZER TRINE, MODEL 240
- (1) KICKPLATE HIAWATHA, MODEL KP834-US32D (INSTALLED ON INTERIOR SIDE OF DOOR)

NEW HARDWARE SETS

SET 1 - MAIN ENTRY - PAIR - WOOD PULL/PUSH

- (2) PUSH HARDWARE 1 1/2" DIAMETER WOOD PUSH, VARIES HIGH - PROVIDED BY MILLWORK SUPPLIER. MOUNT TOP OF PULLS FLUSH WITH TOP OF GLAZING STOP IN DOOR, RE: SHOP DRAWINGS
- (2) PULL HARDWARE 1 1/2" DIAMETER WOOD PULL, VARIES HIGH - PROVIDED BY MILLWORK SUPPLIER. MOUNT TOP OF PULLS FLUSH WITH TOP OF GLAZING STOP IN DOOR, RE: SHOP DRAWINGS

SET 2D - ENTRY - SINGLE - VESTIBULE

- (1) HINGE HAGER, MODEL 780-224HD-83"-CLR
- (1) PUSH HARDWARE HAGER, MODEL 305, 4"X16" US32D STAINLESS STEEL
- (1) PULL HARDWARE HAGER, MODEL 4G US32D (8" CTC.), CENTER ON DOOR STILE
- (1) CLOSER DORMA, MODEL 8916-AF89P-689 (TOP JAMB), (ALUMINUM)
- (1) DOOR STOP IVES, MODEL FS18S (ALUMINUM)
- (1) CLOSER BACK PLATE DORMA, MODEL BP89, ALUMINUM
- (1) KICKPLATE HIAWATHA, MODEL KP834-US32D (SIZE 8" X 34")

SET 4 - MANAGER'S OFFICE

- (3) HINGE STANLEY, MODEL FB8179-4.5-US26 (06-8438)
- (1) LOCKSET SCHLAGE, MODEL L9453L-06A-626
- (1) TEMP CORE SCHLAGE, MODEL 80-035 INTERCHANGEABLE CORE (FINISH: BRUSHED CHROME)
- (1) KICKPLATE HIAWATHA, MODEL KP834-32D
- (1) DOOR STOP DON-JO, MODEL 1407-630, STAINLESS STEEL
- (3) DOOR SILENCERS IVES, MODEL SR64
- (1) CLOSER WINDOW AIR LOUVERS, MODEL VSL1212TEMPPAK SLIMLINE 12" X 12" X 1/4" LITE KIT (10" X 10" GLASS VISIBLE)

SET 5 - TOILET ROOM 2 RESTROOM - SINGLE OCCUPANT - STANDARD


- (3) HINGE STANLEY, MODEL FB8179-4.5-US26 (06-8438)
- (1) CLOSER FALCON, MODEL: SC61xRW/PAXALU
- (1) LOCKSET SCHLAGE, MODEL AL40S-NEP-626
- (1) DOOR STOP DON-JO, 1407-630
- (3) DOOR SILENCERS IVES, MODEL SR64
- (2) KICKPLATE HIAWATHA, MODEL KP834-32D
- (1) COAT HOOK MILLS, MODEL FT6519, SUPPLIED BY WASHROOM ACCESSORIES VENDOR, MOUNT T.O. HOOK AT 47 1/2" AFF

SET 6 - TOILET ROOM 1 RESTROOM - SINGLE OCCUPANT - STANDARD

- (3) HINGE STANLEY, MODEL FB8179-4.5-US26 (06-8438)
- (1) CLOSER FALCON, MODEL: SC61xRW/PAXALU
- (1) LOCKSET SCHLAGE, MODEL AL40S-NEP-626
- (1) DOOR STOP DON-JO, 1407-630
- (3) DOOR SILENCERS IVES, MODEL SR64
- (2) KICKPLATE HIAWATHA, MODEL KP834-32D
- (1) COAT HOOK MILLS, MODEL FT6519, SUPPLIED BY WASHROOM ACCESSORIES VENDOR, MOUNT T.O. HOOK AT 47 1/2" AFF

VESTIBULE FRAME TYPES

*GENERAL NOTES: ALL STOREFRONT TO BE ANODIZED ALUMINUM (COLOR AS NOTED) W/ THERMAL BREAKS; ALL GLAZING TO BE 1/4" CLEAR SAFETY GLAZING U.N.O. PROVIDE HEAD RECEPTORS WHERE NOTED

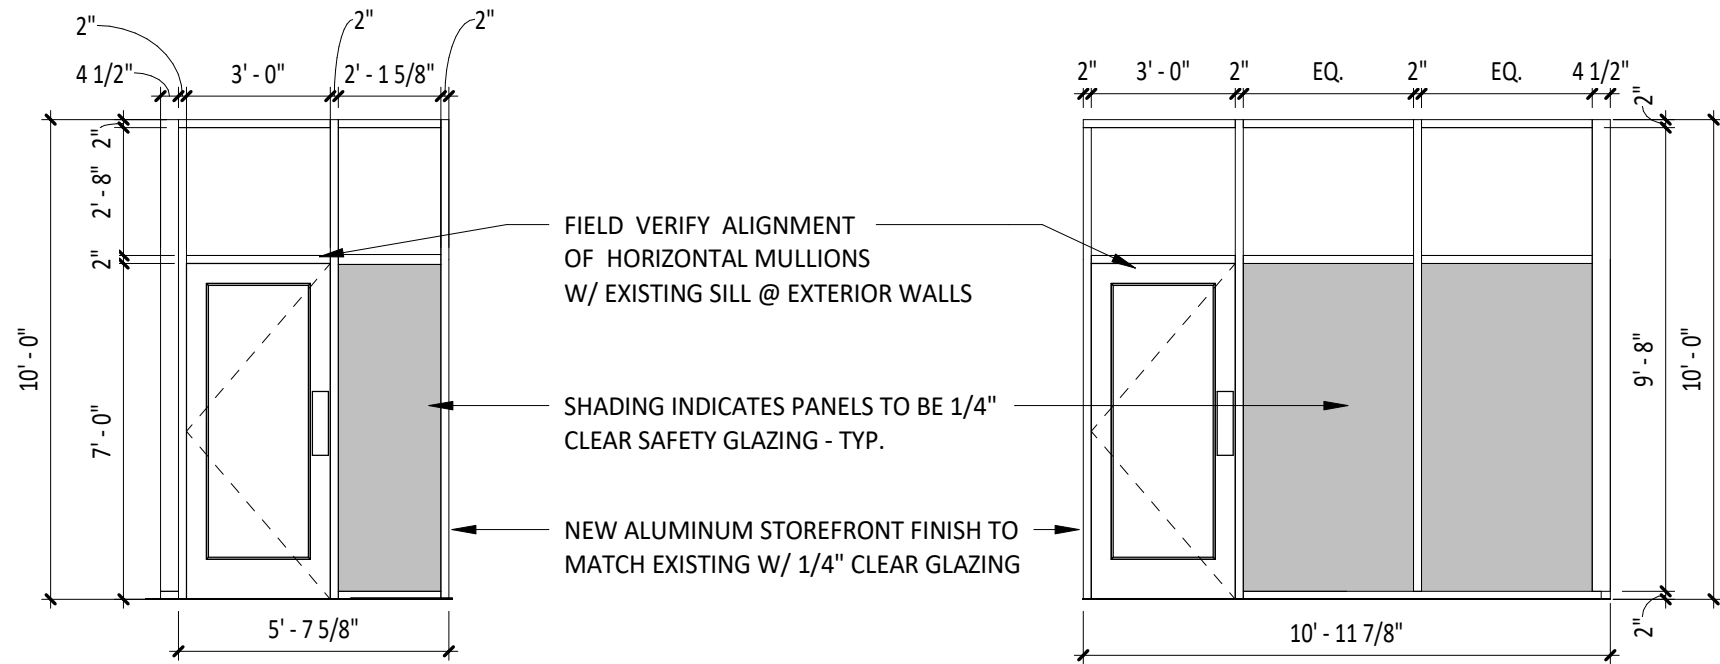


1 STOREFRONT ELEVATION 1
SCALE: 1/4" = 1'-0"

2 STOREFRONT ELEVATION 2
SCALE: 1/4" = 1'-0"


GENERAL DOOR HARDWARE

- A. ALL EGRESS DOORS SHALL BE READILY OPENABLE FROM THE EGRESS SIDE WITHOUT THE USE OF A KEY OR SPECIAL KNOWLEDGE OR EFFORT.
- B. LATCHES, HANDLES, PANIC BARS AND ALL DOOR HARDWARE WILL COMPLY WITH SECTION 7.2 OF NPFA 101 PER THE SPECIFICATIONS.
- C. THE MANAGER HAS A KEY TO UNLOCK RESTROOM DOORS, FROM THE OUTSIDE IN CASE OF AN EMERGENCY.
- D. ALL DOORS TO REMAIN UNLOCKED DURING BUSINESS HOURS.
- E. SEE THIS SHEET FOR EXTERIOR DOOR SIGNAGE INFO.
- F. MAXIMUM EFFORT TO OPERATE EXTERIOR OR INTERIOR DOORS WITH CLOSERS SHALL NOT EXCEED 5 POUNDS. THIS MAY BE INCREASED TO 15 POUNDS FOR FIRE-RATED DOORS.
- G. ALL NEW HOLLOW METAL DOORS, FRAMES AND HARDWARE TO BE FURNISHED BY TENANT HARDWARE SUPPLIER AND INSTALLED BY TENANT G.C. CALL PETE KLIMEK WITH TWIN CITY HARDWARE AT 763-535-4660 TO ARRANGE DELIVERY. NEW VESTIBULE STOREFRONT DOORS AND DOOR HARDWARE ARE TO BE PROVIDED BY TENANT GC.
- H. THE BOTTOM 10 INCHES OF ALL DOORS SHALL HAVE A SMOOTH, UNINTERRUPTED SURFACE TO ALLOW THE DOOR TO BE OPENED BY A WHEELCHAIR FOOTREST WITHOUT CREATING A TRAP OR HAZARDOUS CONDITION.
- J. ALL SUPPORT SIGNAGE INSTALLED BY G.C.
- J. ALL SUPPORT SIGNAGE PROVIDED BY TENANT'S SUPPORT SIGNAGE SUPPLIER.
- K. ALL HARDWARE SHALL MATCH STOREFRONT, VERIFY WITH ARCHITECT AND/OR CHIPOTLE CONSTRUCTION MANAGER PRIOR TO ORDERING.


DOOR FRAME

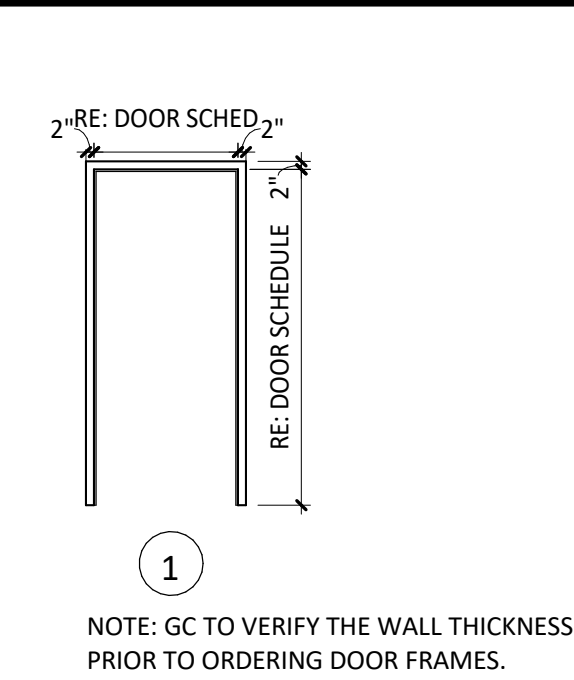


CUSTOM WOOD PULL

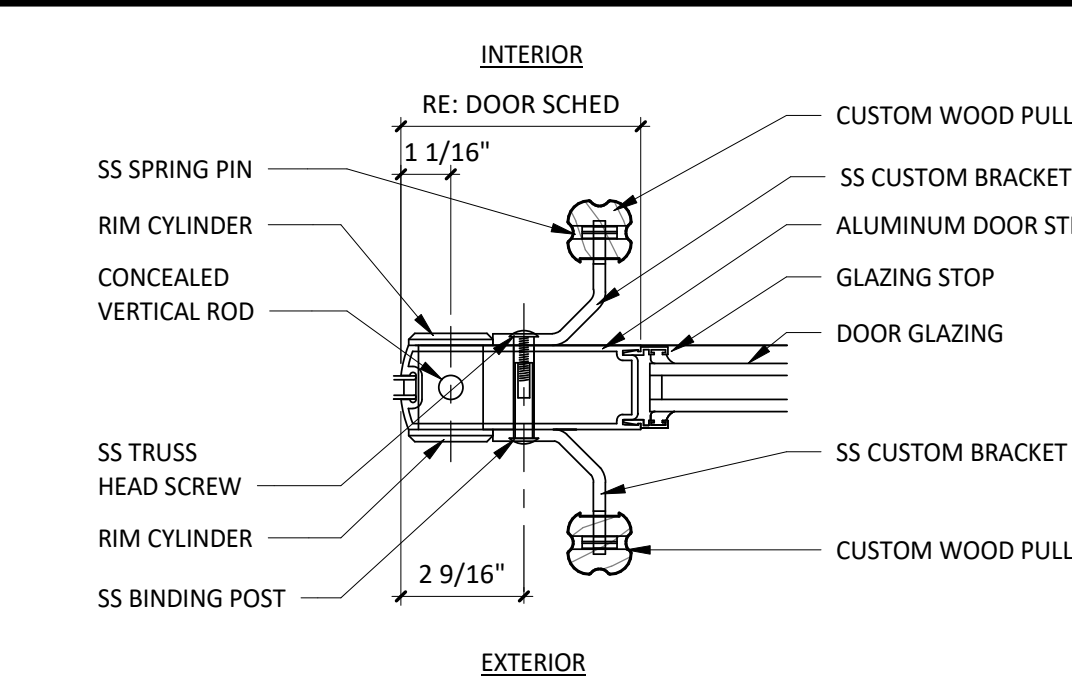


SILL FLASHING

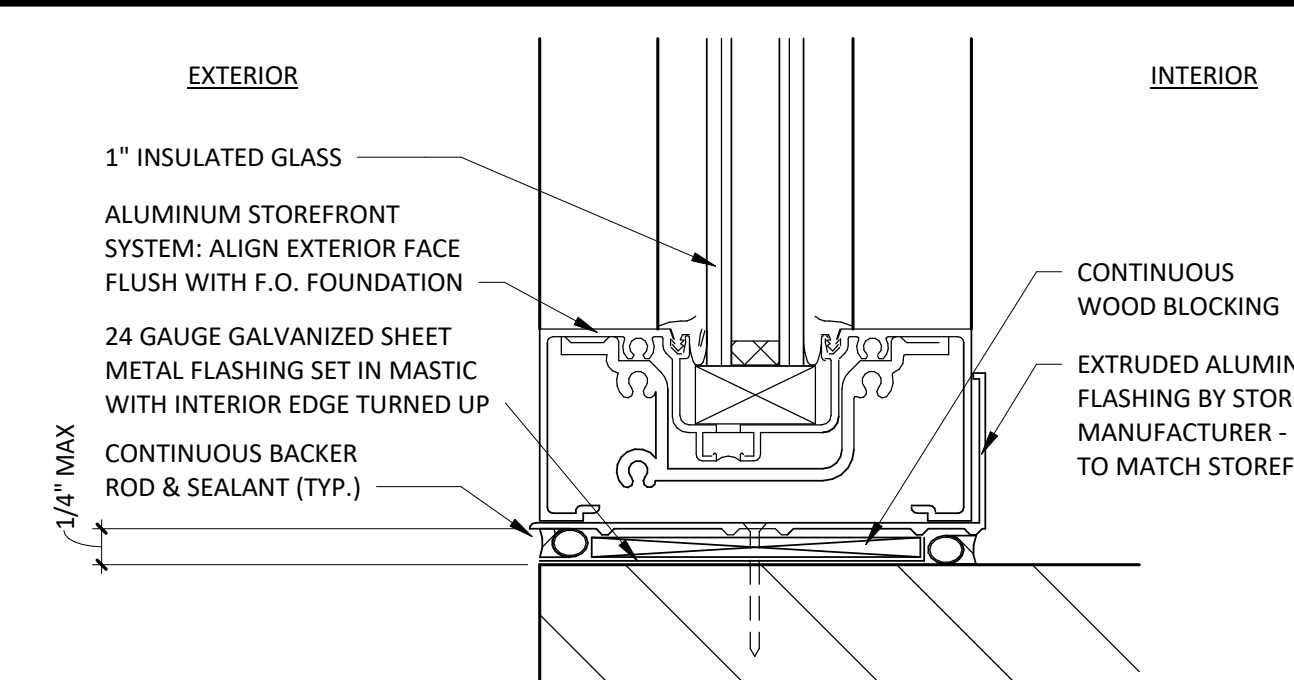

DOOR TYPES

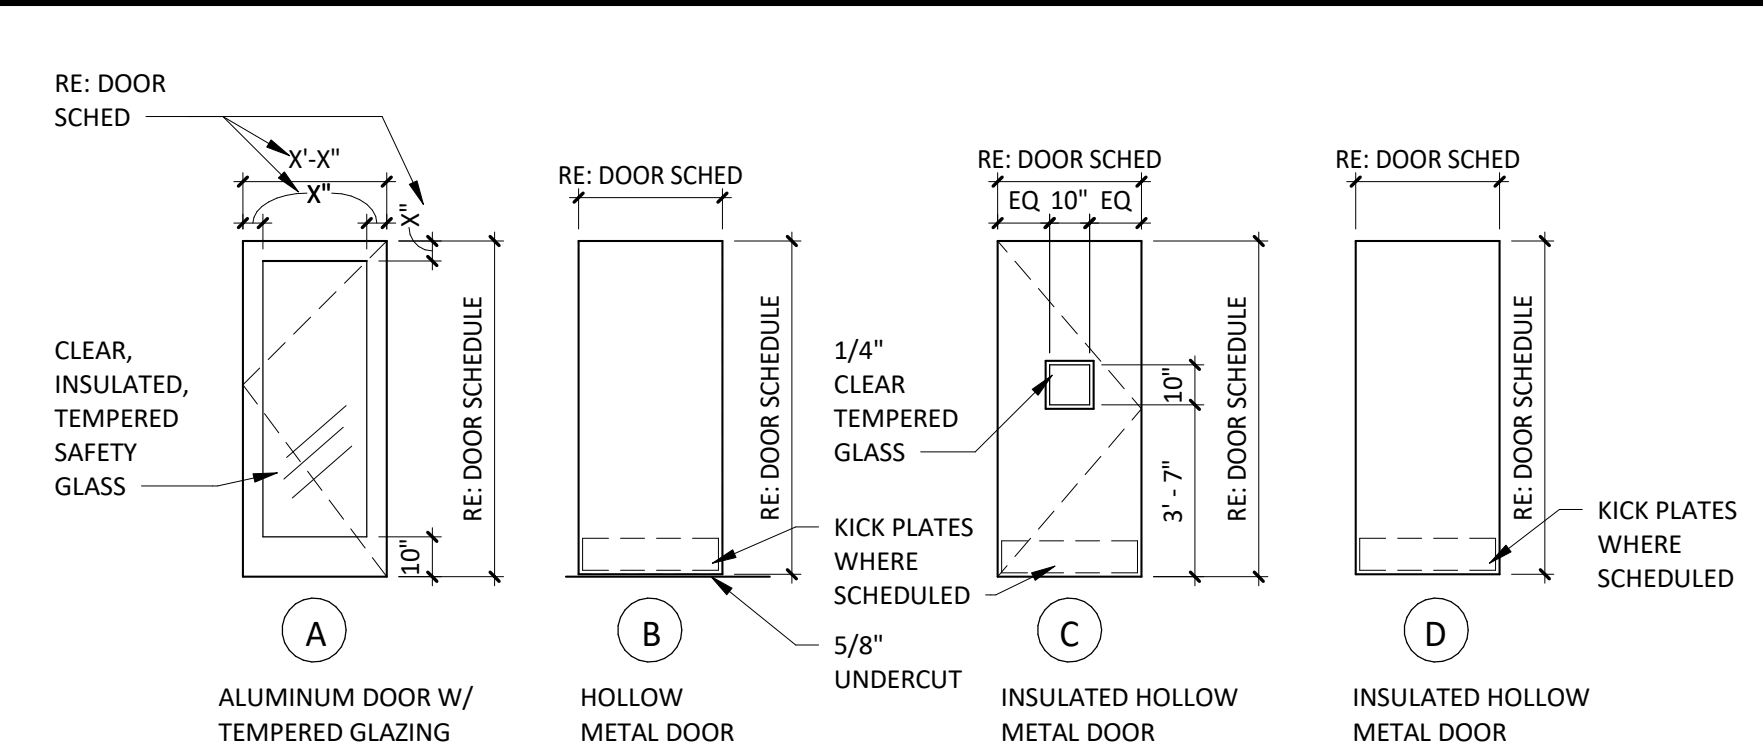

DOOR CLOSER

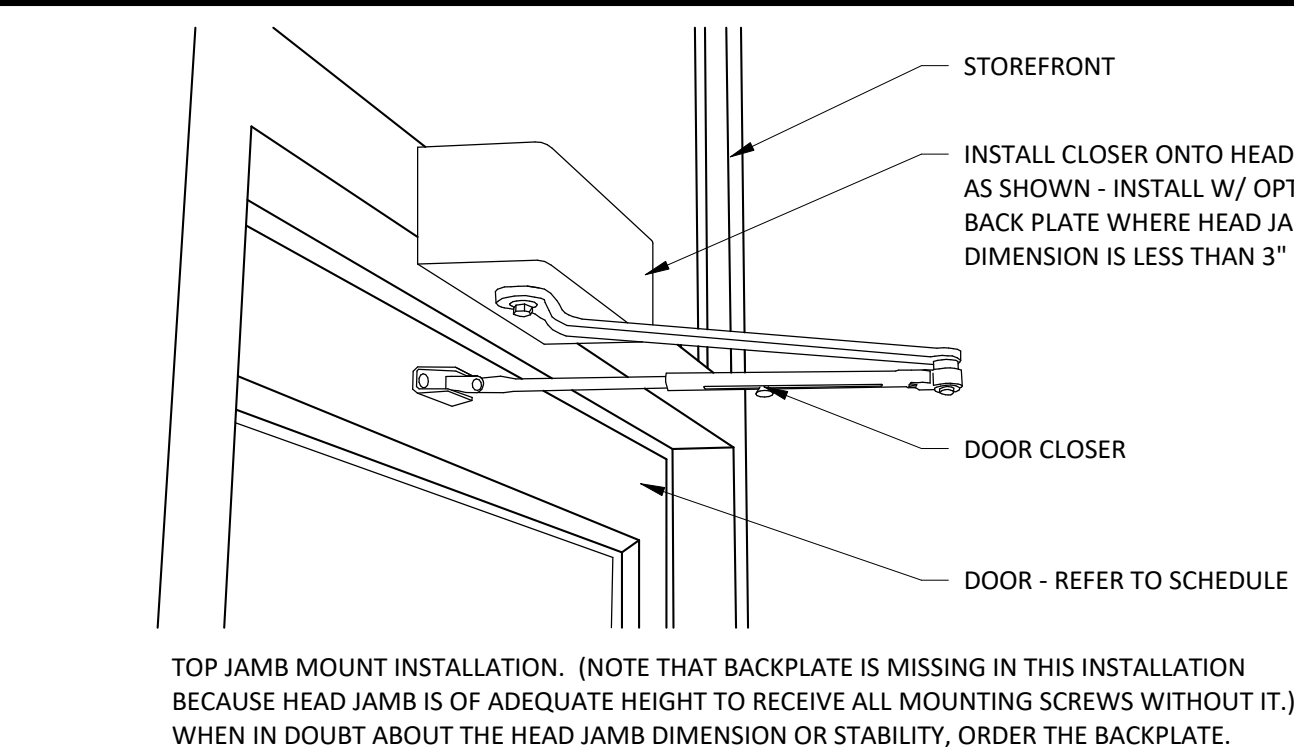

CONSULTANT:



CLIENT:




COPYRIGHT 2024
THIS DRAWING IS AN INSTRUMENT OF SERVICE AND AS SUCH REMAINS THE PROPERTY OF CHIPOTLE MEXICAN GRILL, INC. PERMISSION FOR USE OF THIS DOCUMENT IS LIMITED AND CAN BE EXTENDED ONLY BY WRITTEN AGREEMENT WITH CHIPOTLE MEXICAN GRILL, INC.

PROJECT INFORMATION:

STORE NO.: 5037

HUNTLEY
12990 ROUTE 47, LOT 4B
HUNTLEY, IL 60142

SEAL:

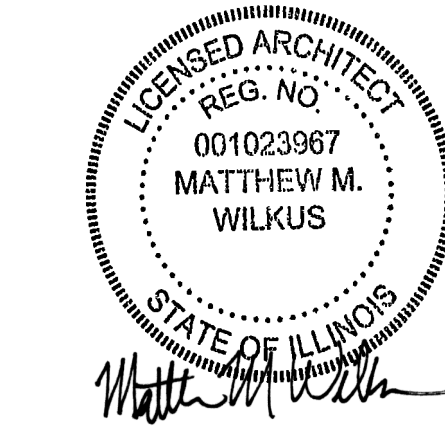

May 06, 2024
MATTHEW M. WILKUS
LICENSE #001,023967
(EXPIRES 11/30/2024)

PROJECT NO. 2023-0175
DRAWN BY JSB, DVA
CHECKED BY DVA, NSG, KAM, MMW

ISSUE RECORD:
02/12/2024 PERMIT SUBMITTAL
03/15/2024 BID SET
05/03/2024 CONSTRUCTION SET



REVISIONS:

TITLE:




DOOR &
HARDWARE
SCHEDULE

SHEET NUMBER:


A601

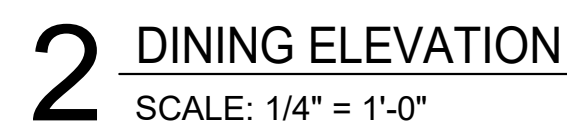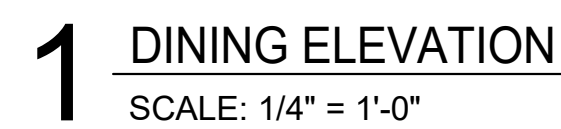


1	SPEAKER LOCATION - REFER TO A201 FOR ADDITIONAL INFORMATION.
2	DUCTWORK SHOWN FOR REFERENCE ONLY - REFER TO MECHANICAL DRAWINGS FOR ALL FINAL DUCTWORK LOCATIONS.
3	SODA CHASE BEYOND - REFER TO PLUMBING DRAWINGS FOR ADDITIONAL INFORMATION.
4	PICK-UP SIGN BY TENANT SIGNAGE VENDOR - INSTALLED BY GENERAL CONTRACTOR - COORDINATE REQUIRED BLOCKING REQUIREMENTS.
5	6 - PANEL ARTWORK LOCATION.
6	EXISTING STRUCTURE TO REMAIN UNPAINTED - REFER TO A140 AND A201 FOR ADDITIONAL INFORMATION.
7	BARNLIGHT FIXTURES TO BE CENTERED OVER HIGHTOP TABLE - REFER TO A211 FOR ADDITIONAL INFORMATION.
8	MILLWORK BY TMS - REFER TO A130 FOR ADDITIONAL INFORMATION.

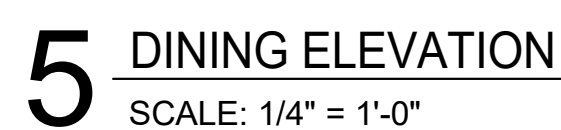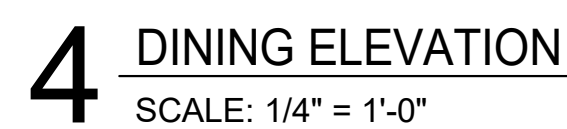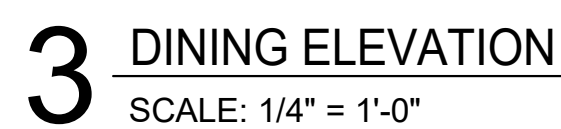


A701

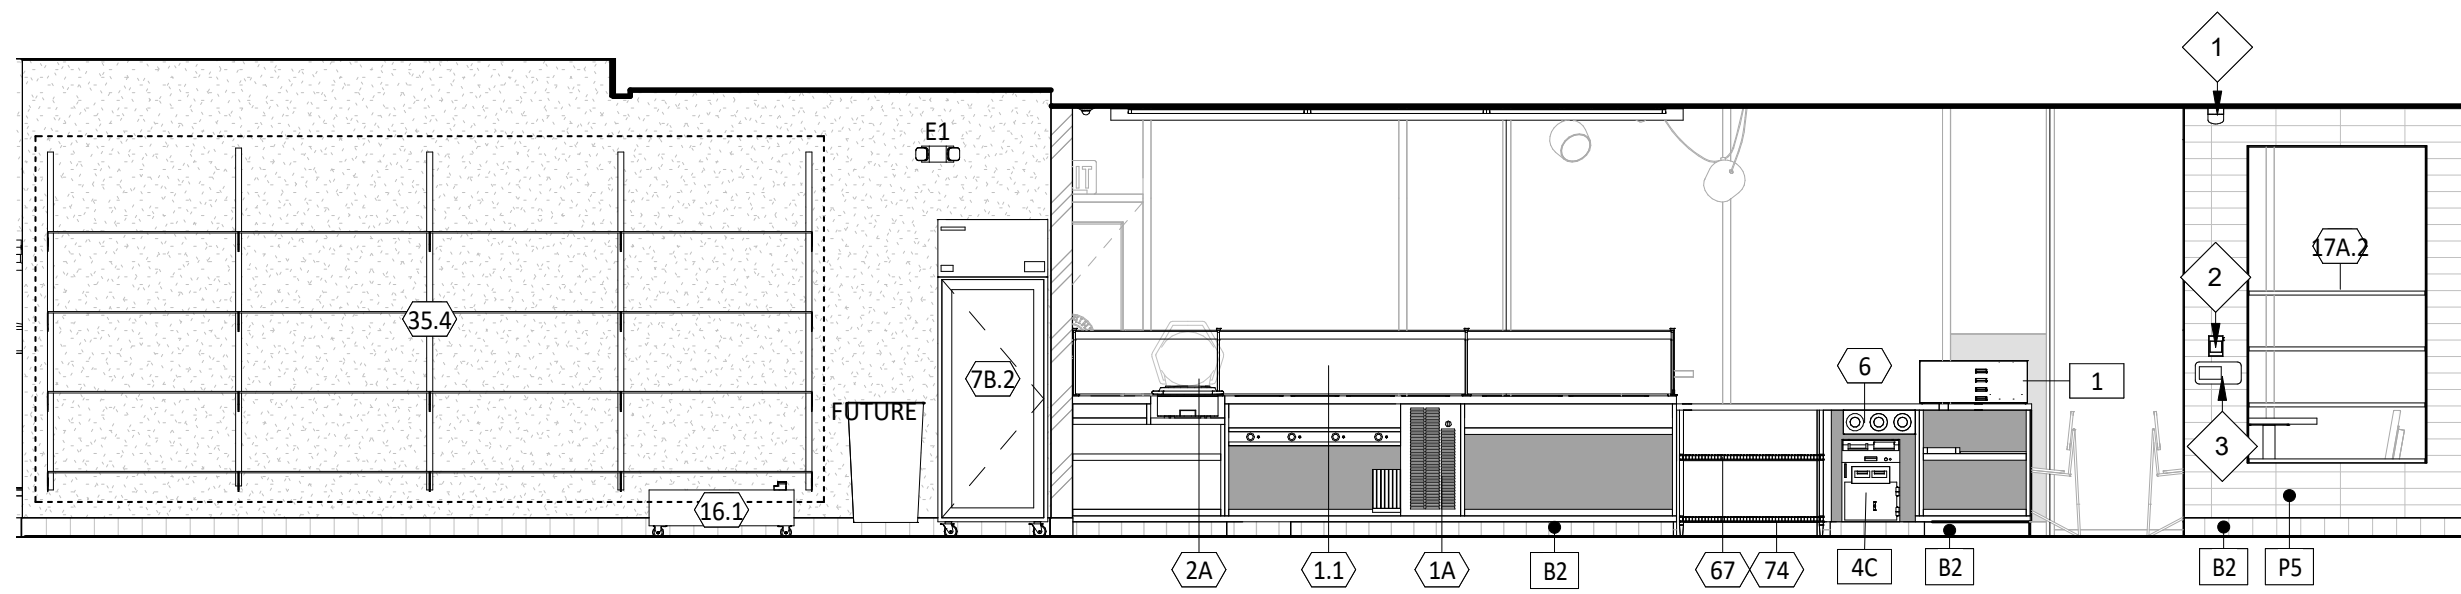


1 INTERIOR ELEVATION
SCALE: 1/4" = 1'-0"

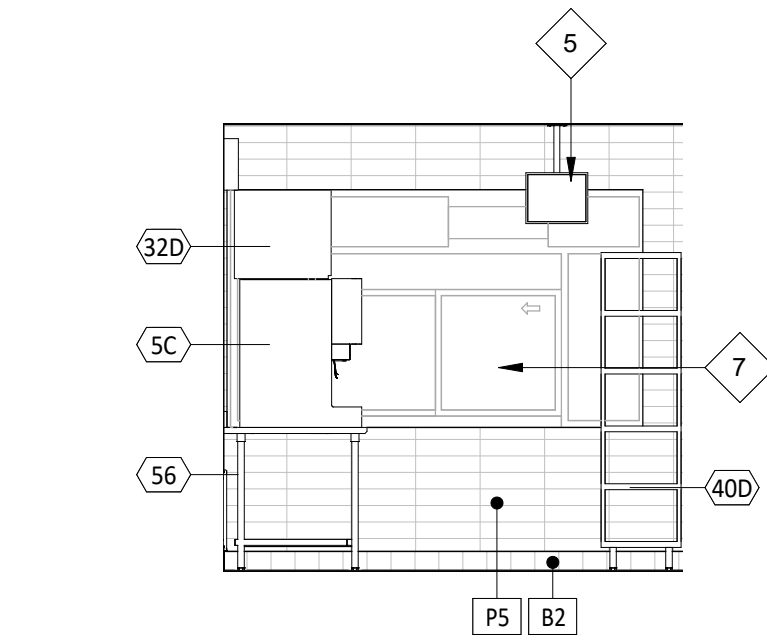


3 INTERIOR ELEVATION
SCALE: 1/4" = 1'-0"

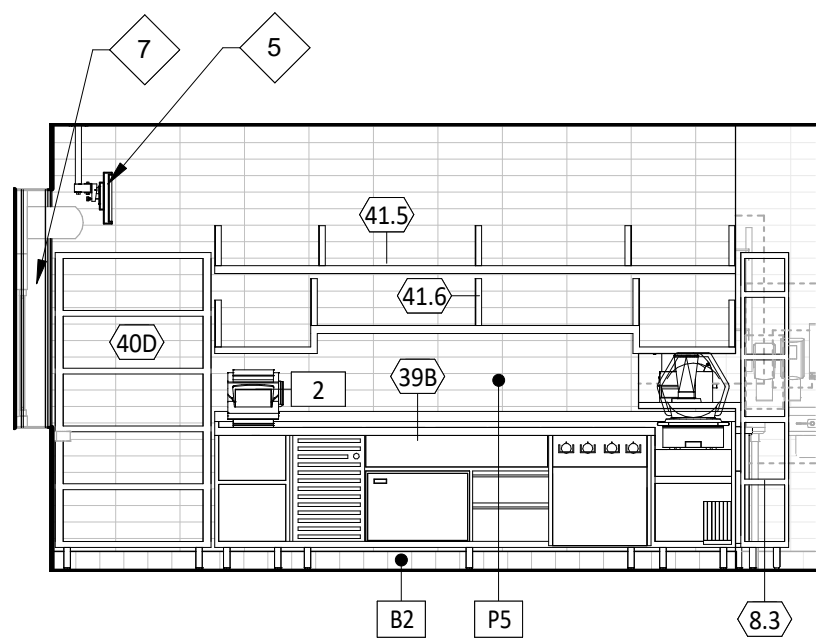


4 INTERIOR ELEVATION
SCALE: 1/4" = 1'-0"

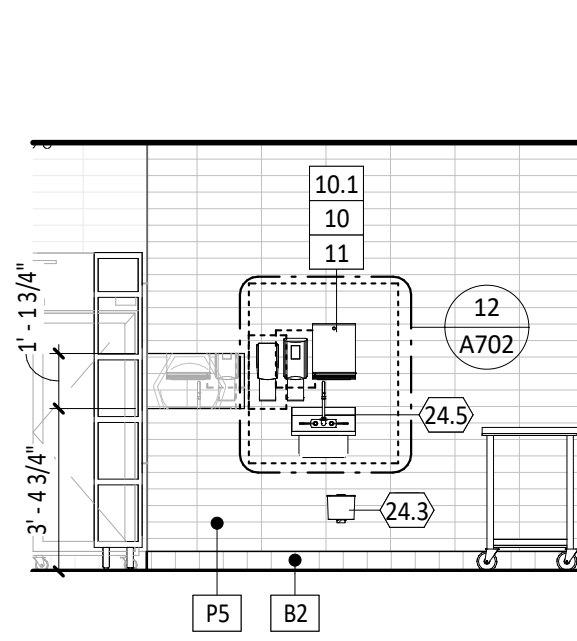


5 INTERIOR ELEVATION
SCALE: 1/4" = 1'-0"

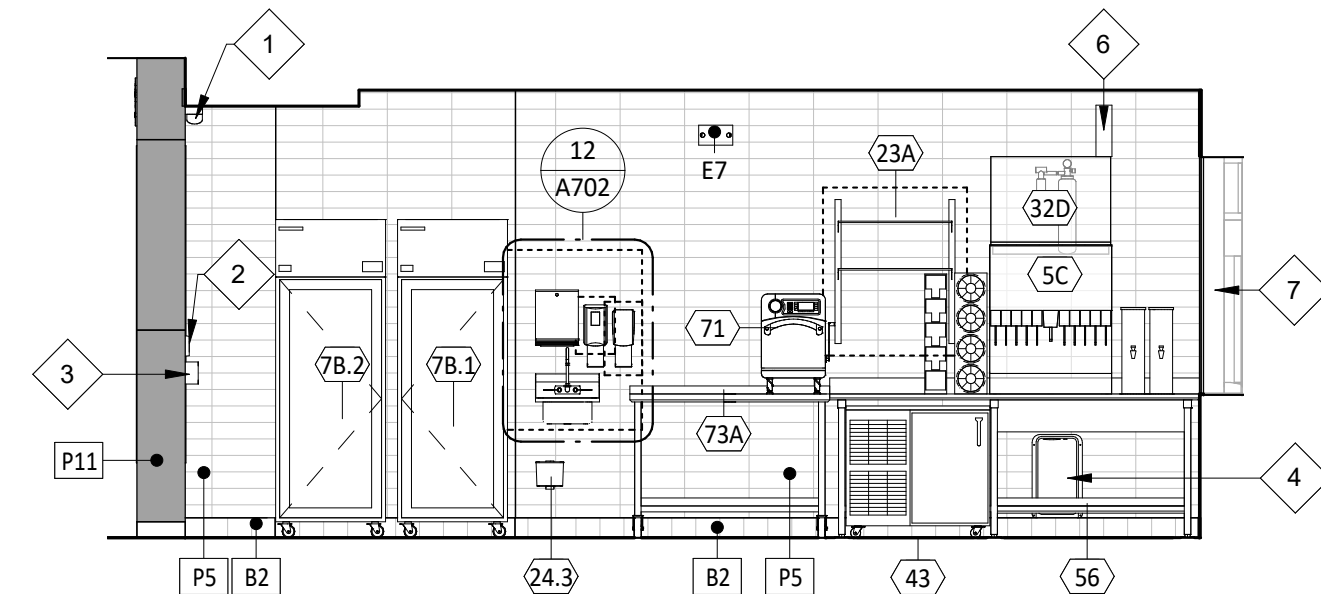


2 INTERIOR ELEVATION
SCALE: 1/4" = 1'-0"

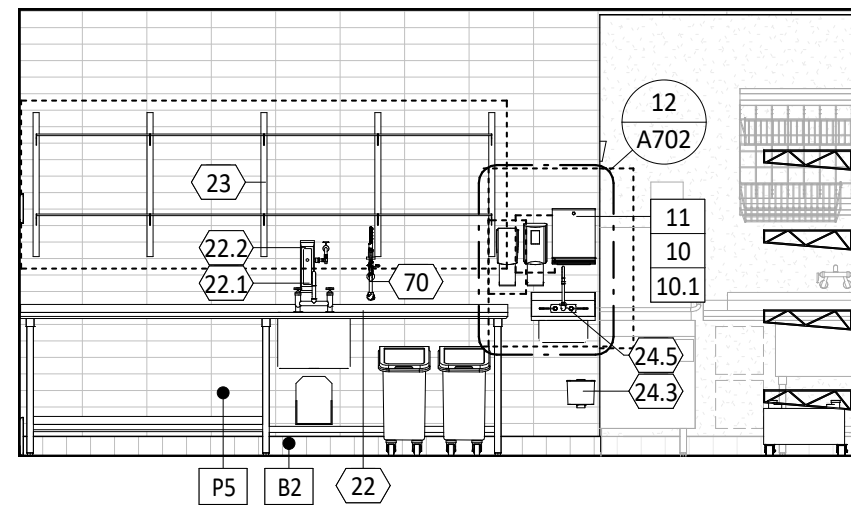


6 INTERIOR ELEVATION
SCALE: 1/4" = 1'-0"

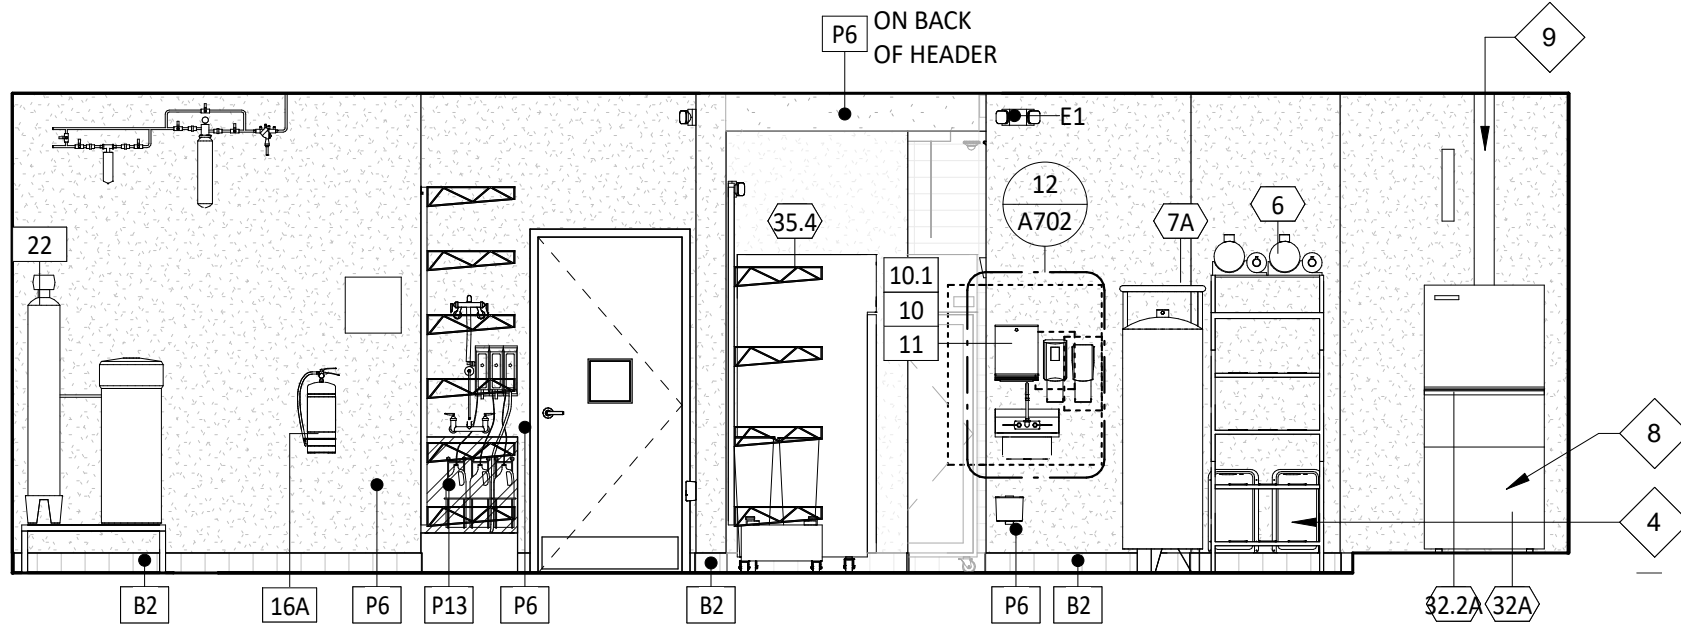


8 INTERIOR ELEVATION
SCALE: 1/4" = 1'-0"

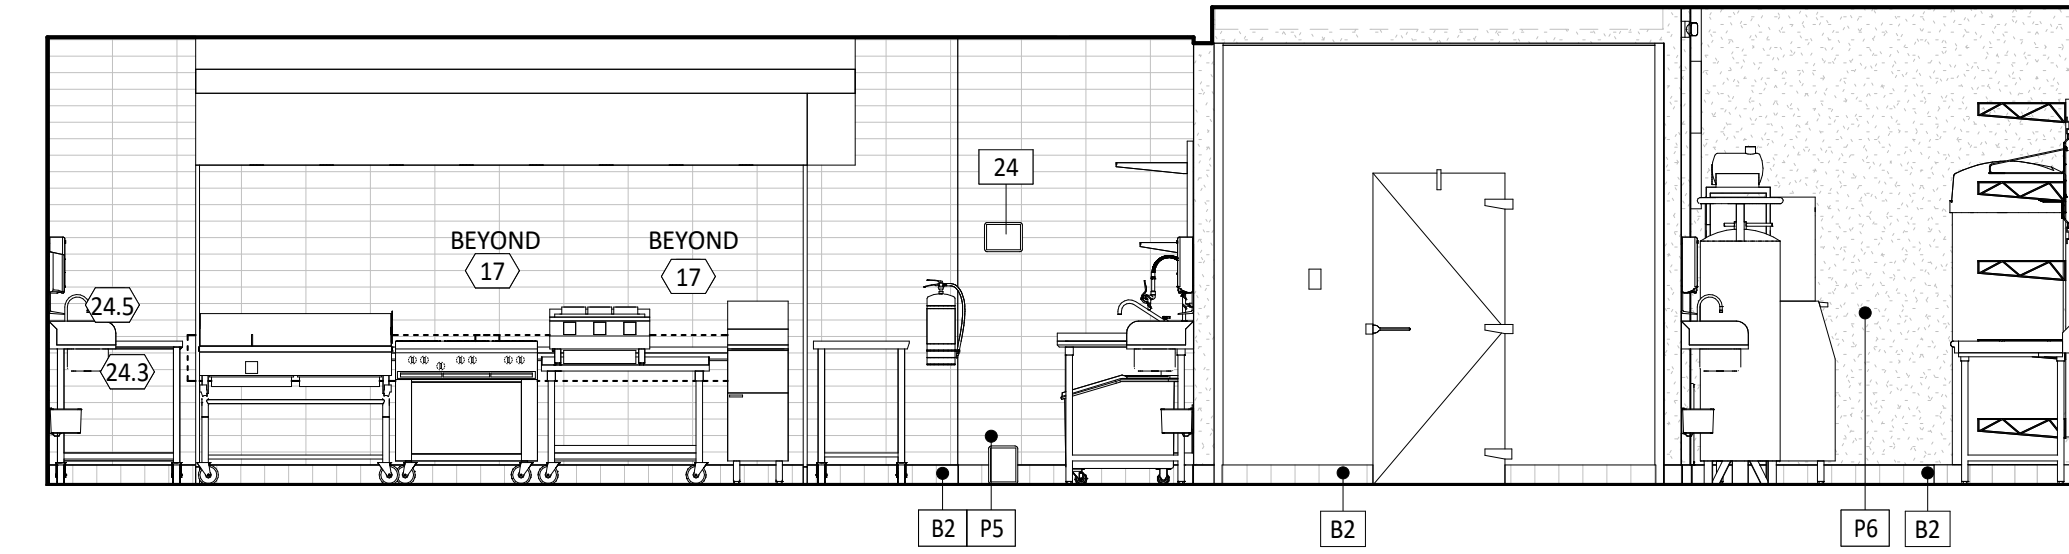


7 INTERIOR ELEVATION
SCALE: 1/4" = 1'-0"

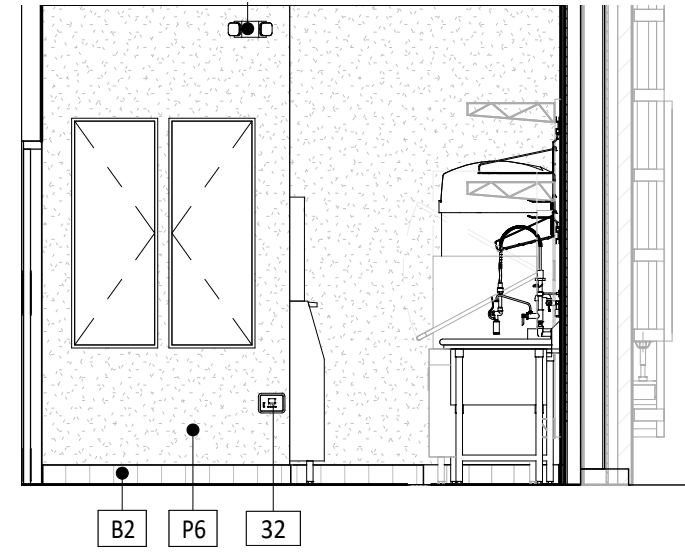


9 INTERIOR ELEVATION
SCALE: 1/4" = 1'-0"

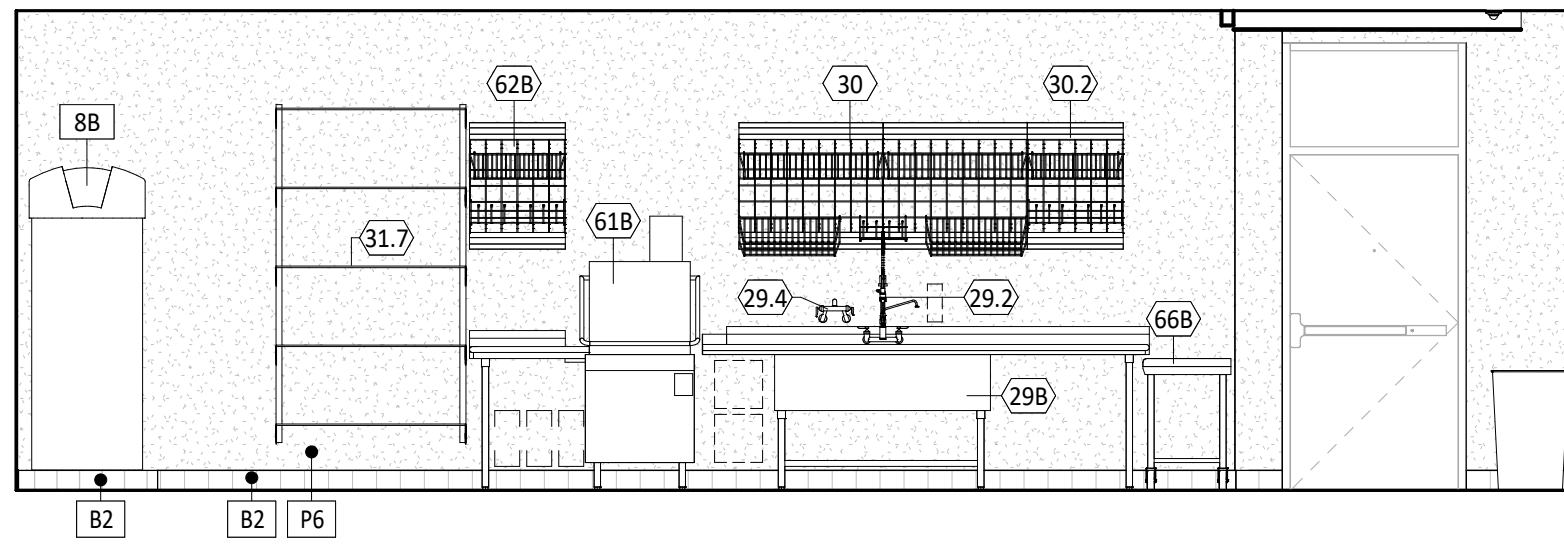


10 INTERIOR ELEVATION
SCALE: 1/4" = 1'-0"

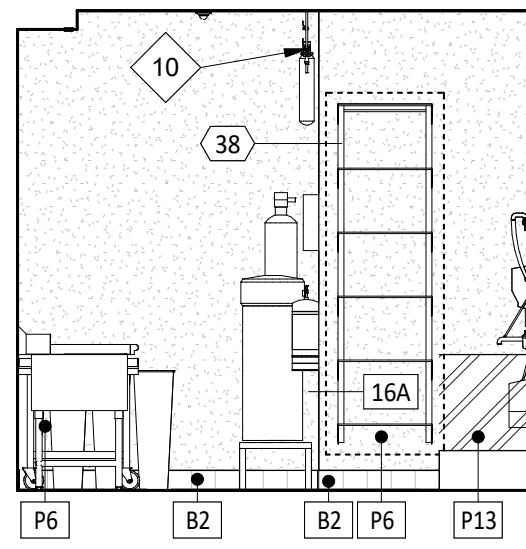


11 INTERIOR ELEVATION
SCALE: 1/4" = 1'-0"

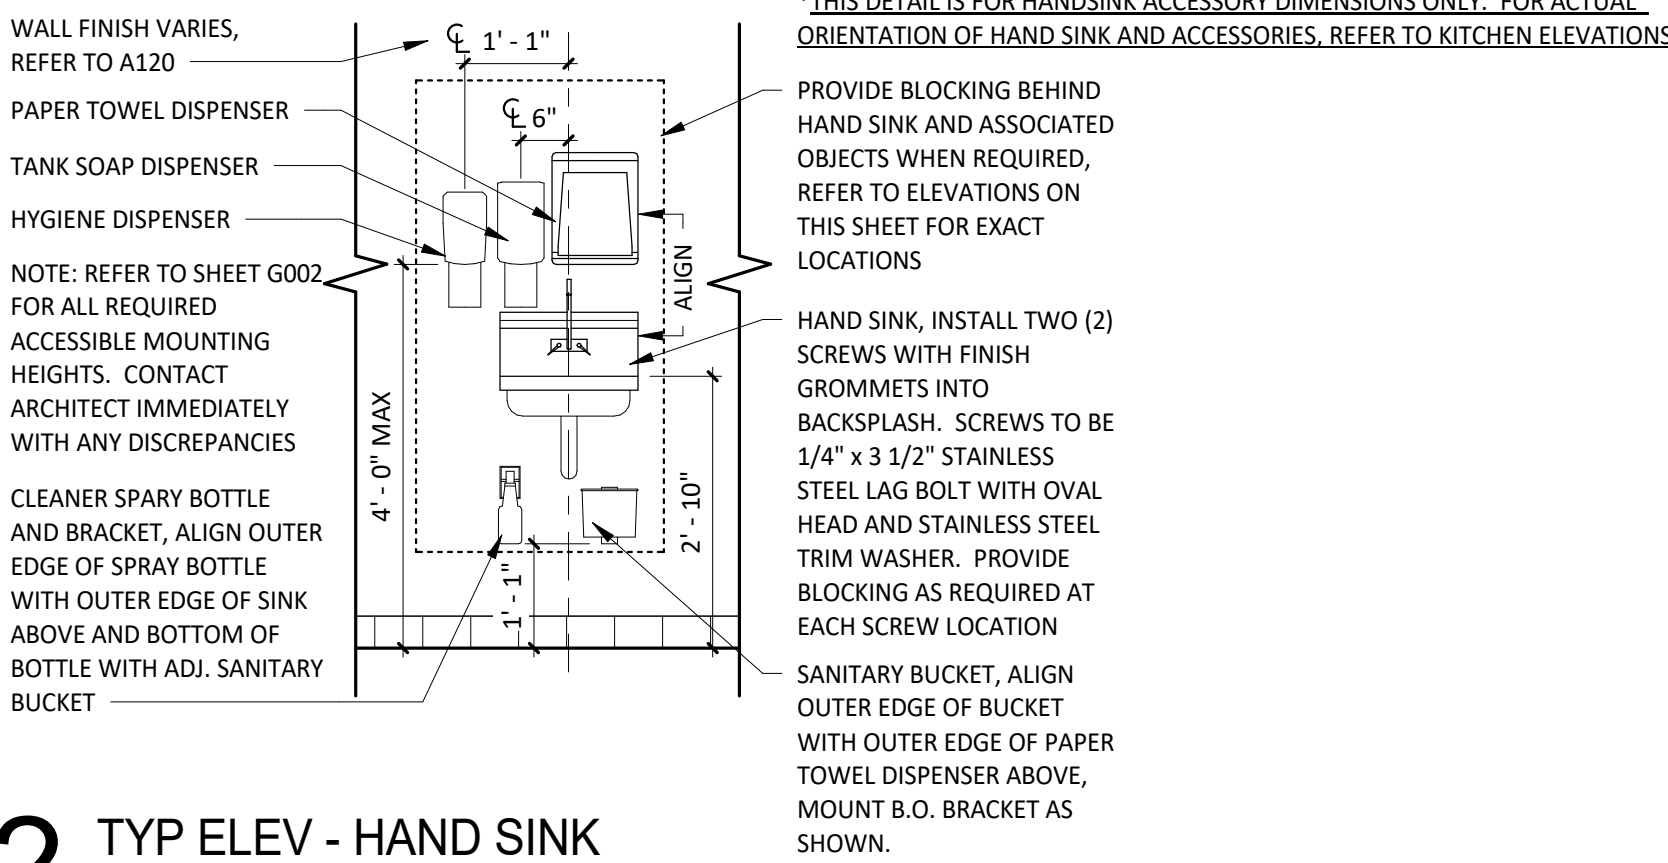

12 TYP ELEV - HAND SINK
SCALE: 1/2" = 1'-0"

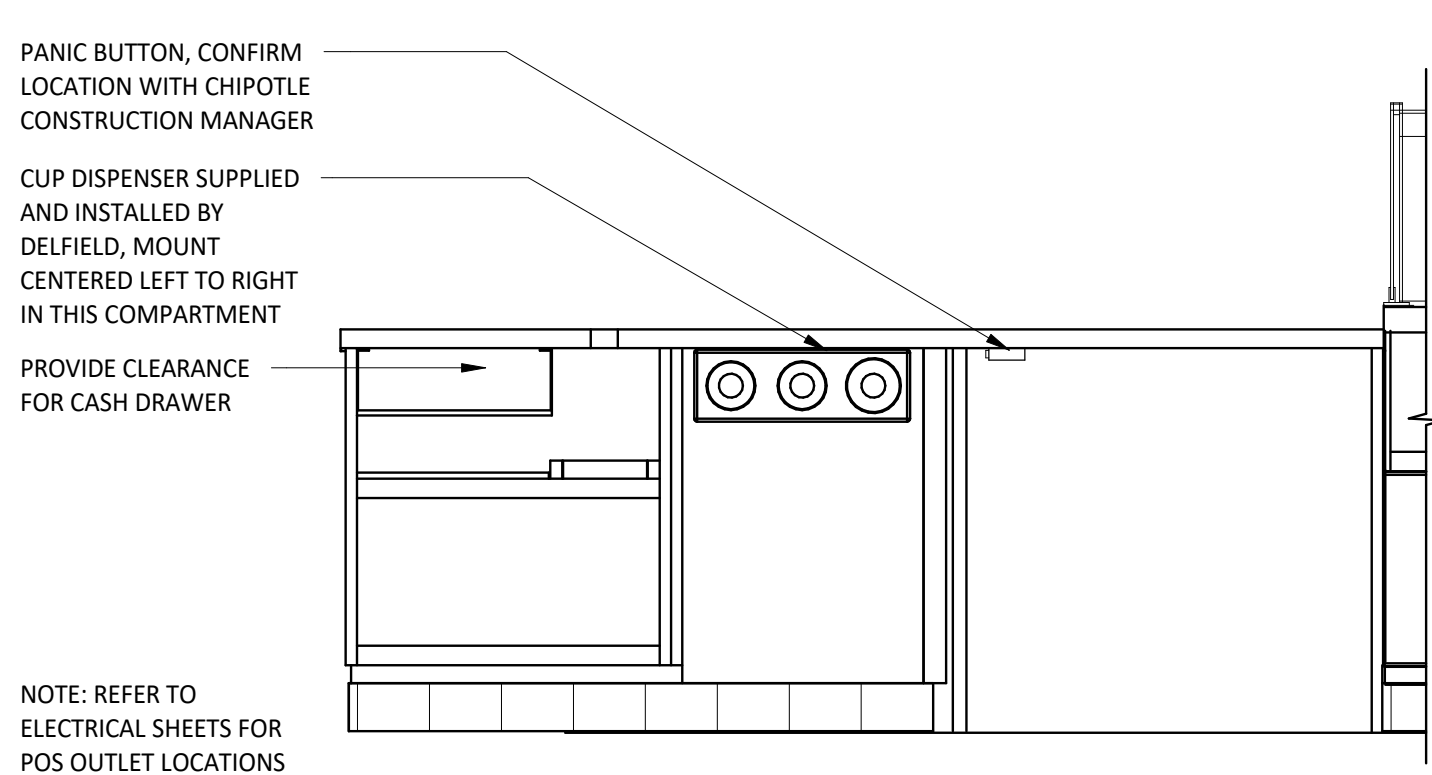

13 TYP. ELEV - POS
SCALE: 3/4" = 1'-0"

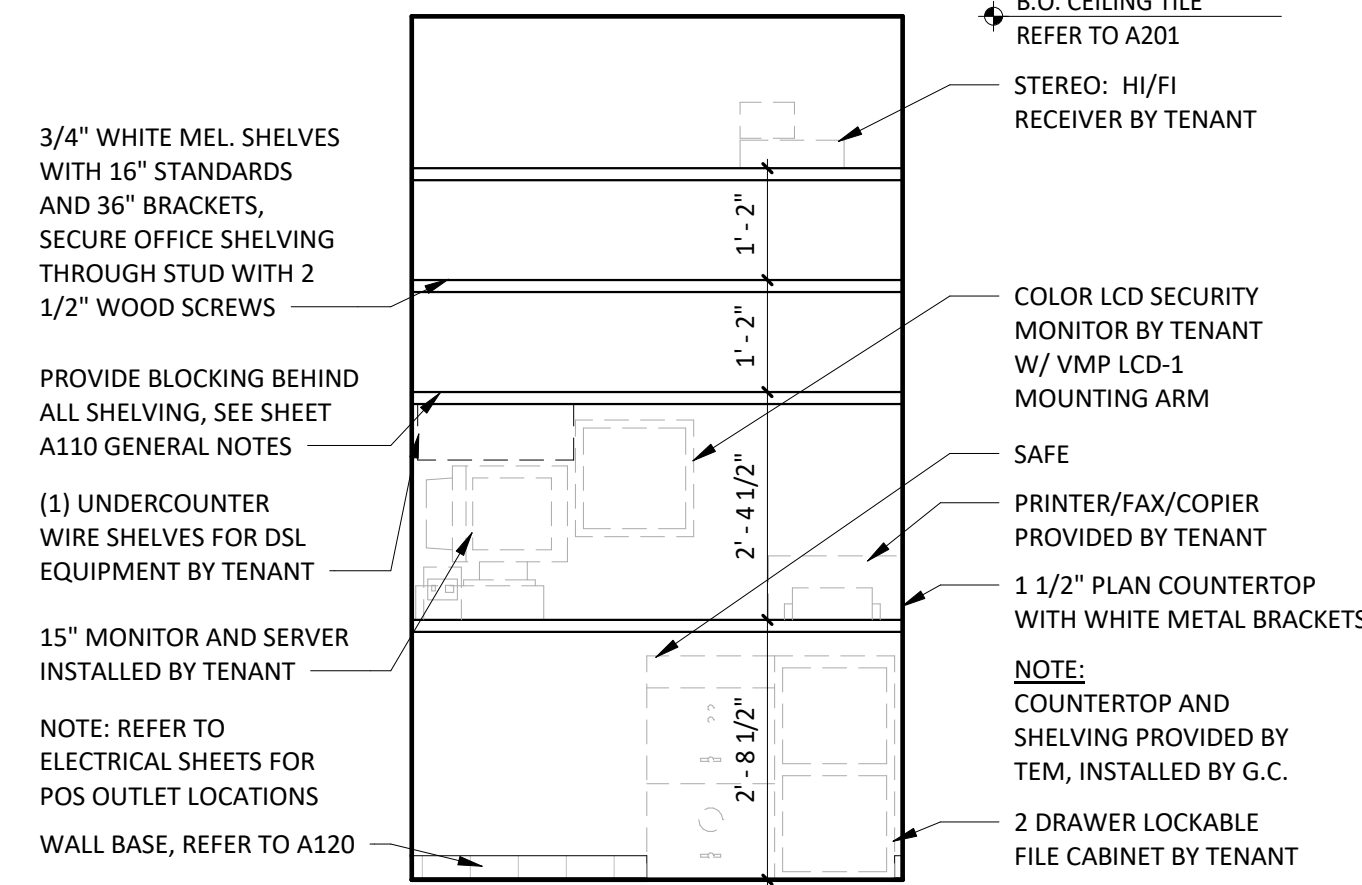

14 TYP ELEV - OFFICE SHELVING
SCALE: 1/2" = 1'-0"

GENERAL NOTES - INT. ELEV.

- REFER TO SHEET A131 FOR EQUIPMENT LIST AND FURNITURE SCHEDULE.
- PROVIDE FULL HEIGHT BLOCKING IN WALL FOR ALL SHELVING, TYP.
- REFER TO A120 FOR FINISH LEGEND.
- REFER TO A201 AND ELECTRICAL DRAWINGS FOR LIGHT FIXTURE SCHEDULE.

ELEVATION LEGEND

- DENOTES WOOD BLOCKING IN WALL BEHIND WALL MOUNTED OBJECT U.N.O.

KEYNOTE LEGEND

- CHIME/STROBE - REFER TO ELECTRICAL SHEETS FOR ADDITIONAL INFORMATION.
- ANSUL PULL TO BE LOCATED 48" A.F.F. TO THE CENTER OF UNIT ABOVE THE TIMECLOCK LOCATION.
- KRONOS TIMECLOCK WILL BE LOCATED 44" A.F.F. TO THE TOP OF UNIT - CENTER KRONOS UNIT IN WALL - REFER TO ELECTRICAL DRAWINGS.
- SODA CHASE BEYOND - REFER TO PLUMBING DRAWINGS FOR ADDITIONAL INFORMATION.
- MONITOR BY TENANTS VENDOR.
- STAINLESS STEEL SHROUD, REFER TO FINISH PLAN FOR DETAILS
- ALUMINUM PLATE SILL, HEAD AND JAMBS AS INDICATED - REFER TO DETAILS 12 & 13/A802.
- MOVEABLE BACK-UP TRASH BINS FOR DINING AREA TRASH SURROUNDS - TYPICAL OF FOUR (4).
- GENERAL CONTRACTOR TO PROVIDE STAINLESS STEEL SHROUD AROUND EXPOSED LINES AT ICE MAKERS - REFER TO FINISH PLANS FOR DETAILS.
- WATER FILTER - REFER TO PLUMBING SHEETS FOR ADDITIONAL INFORMATION.

CONSULTANT:



CLIENT:




COPYRIGHT 2024
THIS DRAWING IS AN INSTRUMENT OF SERVICE AND AS SUCH REMAINS THE PROPERTY OF CHIPOTLE MEXICAN GRILL, INC. PERMISSION FOR USE OF THIS DOCUMENT IS LIMITED AND CAN BE EXTENDED ONLY BY WRITTEN AGREEMENT WITH CHIPOTLE MEXICAN GRILL, INC.

PROJECT INFORMATION:

STORE NO.: 5037
HUNTLEY
12990 ROUTE 47, LOT 4B
HUNTLEY, IL 60142

SEAL:

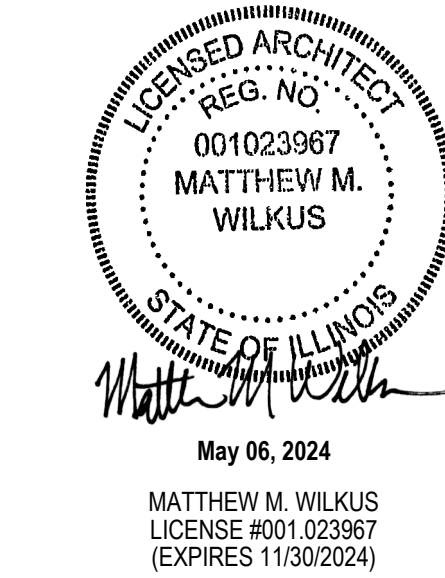

PROJECT NO. 2023-0175
DRAWN BY JSB, DVA
CHECKED BY DVA, NSG, KAM, MMW

ISSUE RECORD:
02/12/2024 PERMIT SUBMITTAL
03/15/2024 BID SET
05/03/2024 CONSTRUCTION SET

REVISIONS:

TITLE:
ELEVATIONS -
INTERIOR KITCHEN

SHEET NUMBER:

A702

RESTROOM ACCESSORIES

ITEM #	DESCRIPTION	MANUF	MODEL	QTY	PROVIDED BY	INSTALLED BY	UTILITY				MOUNTING HEIGHT	REMARKS
							ELEC	GAS	WATER	SEWER		
1A	Grab Bar - 36in	ASI	3501-36	2	WA	GC					34" AFF to Centerline of Grasping Surface	Provide Plywood Blocking to Mount to Wall
1C	Grab Bar - 18in	ASI	3501-18	2	WA	GC					40" AFF to Centerline of Bottom Return	Provide Plywood Blocking to Mount to Wall
1D	Grab Bar - 48in	ASI	3501-48	2	WA	GC					36" AFF to Top of Grasping Surface	Provide Plywood Blocking to Mount to Wall
3	Vandal Proof Mirror	Sentry Mirror	20" x 30" Vandal Proof Mirror	2	TS	GC					Bottom Edge of Reflecting Surface at 40" AFF	Provide Plywood Blocking to Mount to Wall
5	Touch-Free Soap Dispenser	Purell	CS8	2	WA	GC					47 1/2" AFF To Top Of Dispenser	
7	Recessed Toilet Paper Dispenser	ASI	0031	2	WA	GC					29" AFF to Top of Unit	Recess Mounted in Wall - Rough Opening: 6 1/4"W X 12 1/4"H X 3 3/8"D Top of Rough Opening: 29 1/4" AFF Provide Toggle Bolts to Mount to Wall
8	Utility Shelf	ASI	0692	1	WA	GC					46" AFF To Top Of Shelf	Provide Toggle Bolts to Mount to Wall
9	Recessed Convertible Paper Towel Dispenser and Waste Receptacle, Recess Mounted in Wall	Bobrick	B-3944	2	WA	GC					Bottom of Unit at Top of Base, Bottom of Dispenser to be at 40" AFF, Recess Mounting In Wall	Rough Opening: 16"W x 54 3/4"H x 4" D. Provide Plywood Blocking to Mount to Wall
12	Napkin Disposal - Recessed	ASI	0473	2	WA	GC					Top of Rough Opening @ 29" AFF	Recess Mounted in Wall - Rough Opening: 11 1/4"W X 15 3/4"H X 4"D
14	Restroom Hand Sink	Kohler	K-2084	2	GC	GC					Mount Bottom of Front Edge Of The Sink At Exactly 29" AFF	
14.1	Restroom Hand Sink Faucet	SEE MEP	SEE MEP	2	KES	GC						To Be Furnished With .5 GPM Aerator Installed. Thermostatic mixing valve is also included.
15	Hand Sanitizer Dispenser	Purell	ES8	2	WA	GC					Align T.O. Unit With T.O. Soap Dispenser	
16a	Surface Mounted Horizontal Baby Changing Station	Koala Care	KB300-05	2	WA	GC					Mount Bottom of Open Changing Bed at Exactly 27" AFF	GC to Provide adequate blocking to support the baby changing equipment. Blocking shall be installed in such a manner to not damage or compromise the rated assembly of the existing wall construction

GENERAL NOTES - RESTROOM

- A. ALL DIMENSIONS ARE TO FACE OF STUD UNLESS OTHERWISE NOTES.
- B. REFER TO A801 FOR FINISH DETAIL NOTES.
- C. ALL ACCESSORIES SHALL BE AS MANUFACTURED BY AMERICAN SPECIALTIES INC OR TENANT-APPROVED EQUIVALENT UNLESS DESIGNATED OTHERWISE. PROVIDE SOLID FRT WOOD BLOCKING AS NECESSARY FOR INSTALLATION PER MANUFACTURER'S RECOMMENDATIONS. SEE SHEET G002 FOR ACCESSIBILITY GUIDELINES & MOUNTING HEIGHT REQUIREMENTS.
- D. REFER TO A120 FOR FINISH SCHEDULE.
- E. REFER TO A201 AND ELECTRICAL DRAWINGS FOR LIGHT FIXTURE SCHEDULE.

ELEVATION LEGEND

⬡ DENOTES WOOD BLOCKING IN WALL BEHIND WALL MOUNTED OBJECT U.N.O.

CONSULTANT:



CLIENT:




COPYRIGHT 2024
THIS DRAWING IS AN INSTRUMENT OF SERVICE AND AS SUCH REMAINS THE PROPERTY OF CHIPOTLE MEXICAN GRILL, INC. PERMISSION FOR USE OF THIS DOCUMENT IS LIMITED AND CAN BE EXTENDED ONLY BY WRITTEN AGREEMENT WITH CHIPOTLE MEXICAN GRILL, INC.

PROJECT INFORMATION:

STORE NO.: 5037
HUNTLEY
12990 ROUTE 47, LOT 4B
HUNTLEY, IL 60142

SEAL:

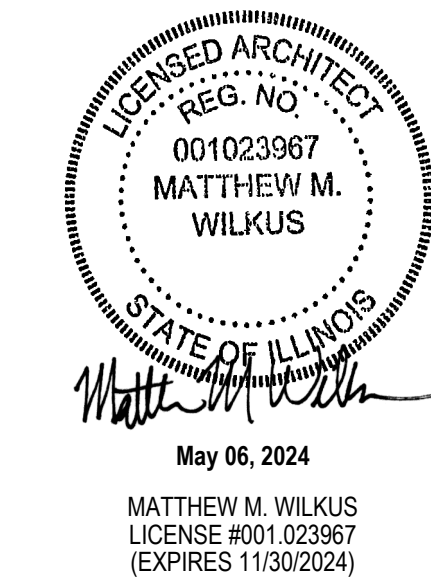

PROJECT NO. 2023-0175
DRAWN BY JSB, DVA
CHECKED BY DVA, NSG, KAM, MMW

ISSUE RECORD:
02/12/2024 PERMIT SUBMITTAL
03/15/2024 BID SET
05/03/2024 CONSTRUCTION SET


REVISIONS:

TITLE:


RESTROOM INFORMATION

SHEET NUMBER:


A710

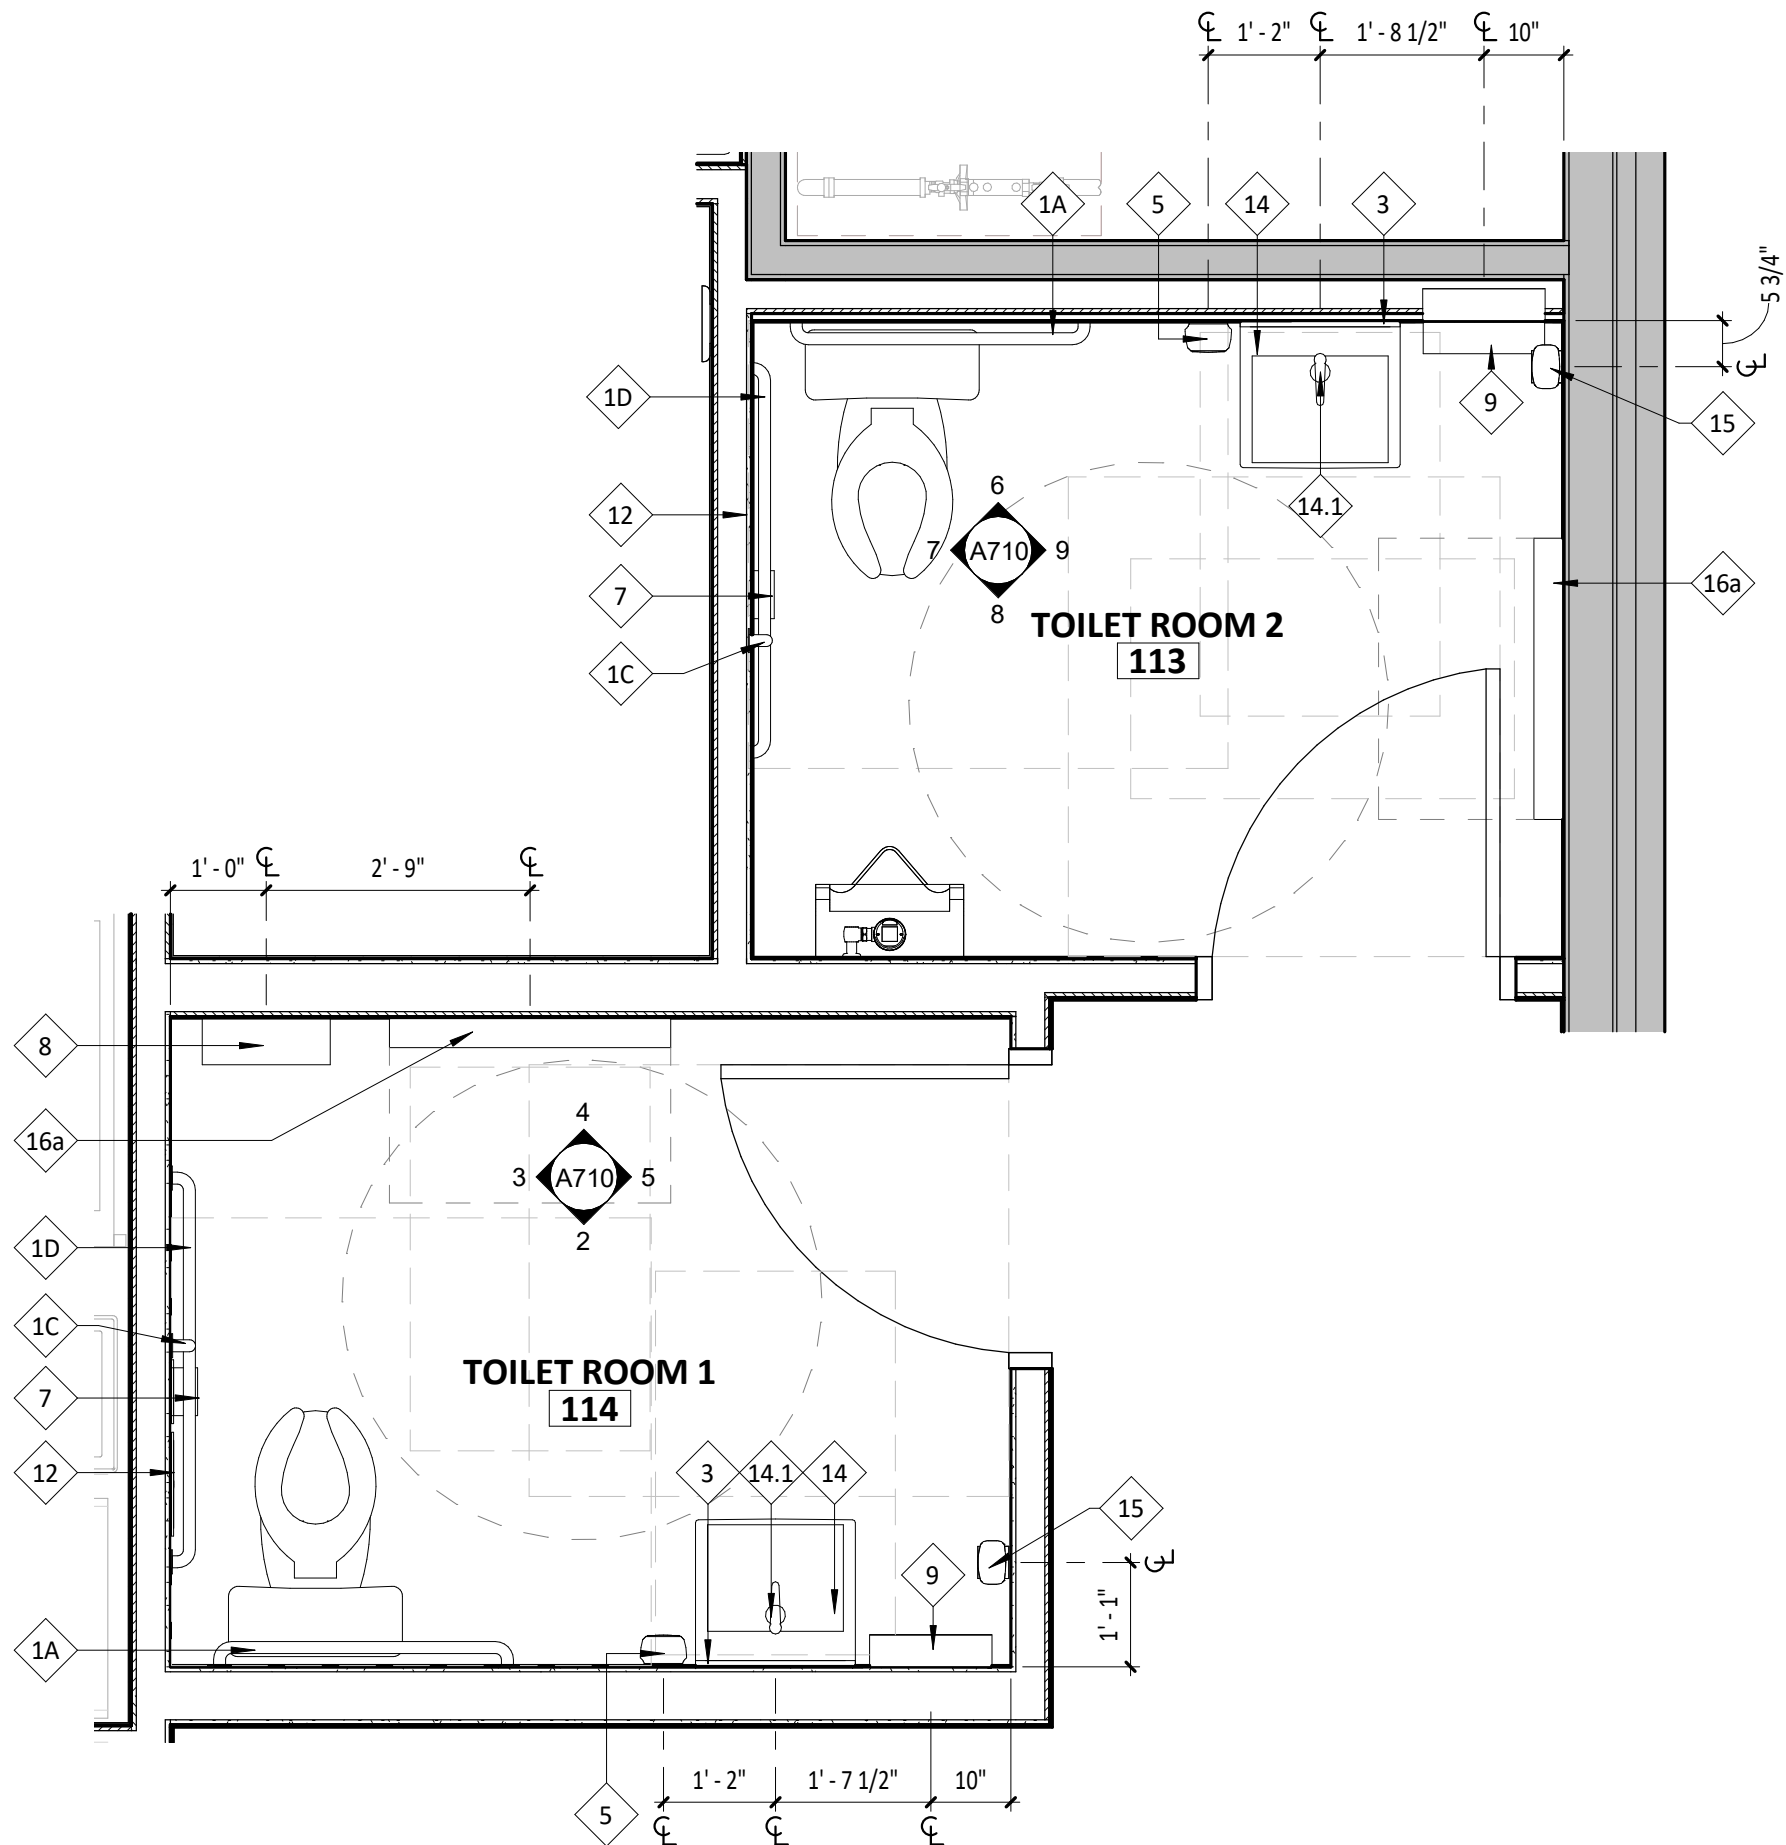


1 ENLARGED PLAN
SCALE: 1/2" = 1'-0"

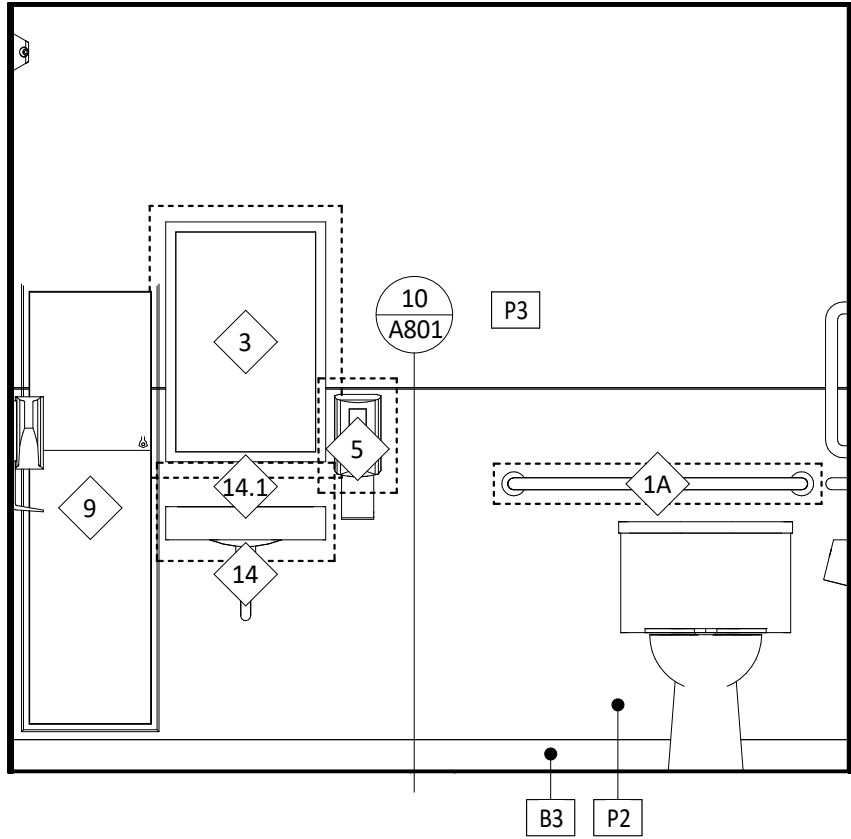


2 UNISEX 1 RESTROOM
SCALE: 1/2" = 1'-0"

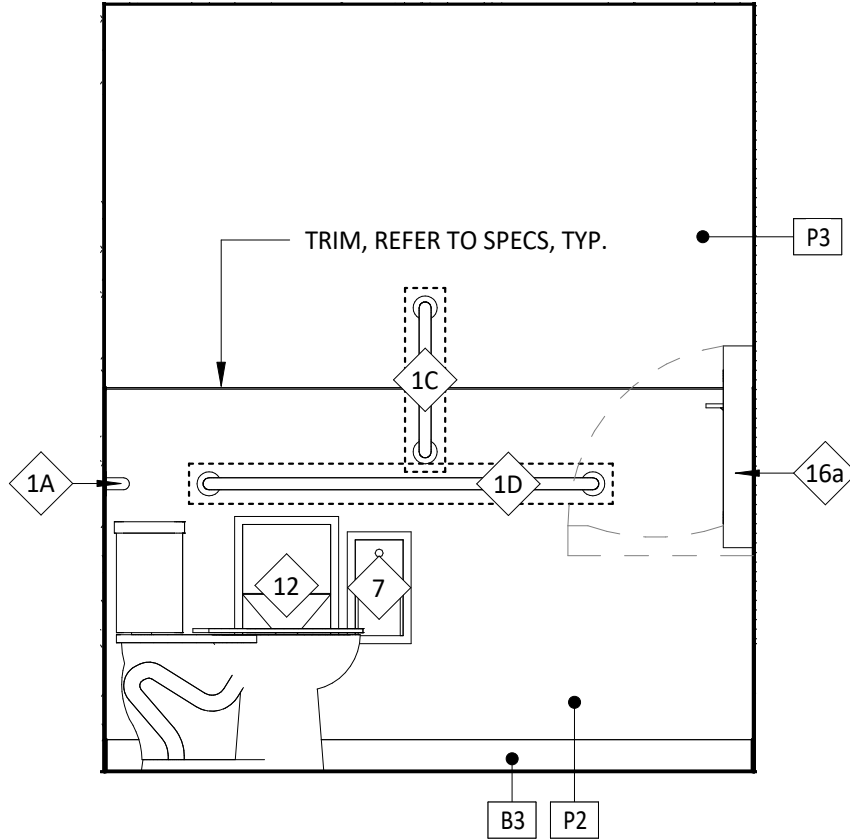


3 UNISEX 1 RESTROOM
SCALE: 1/2" = 1'-0"

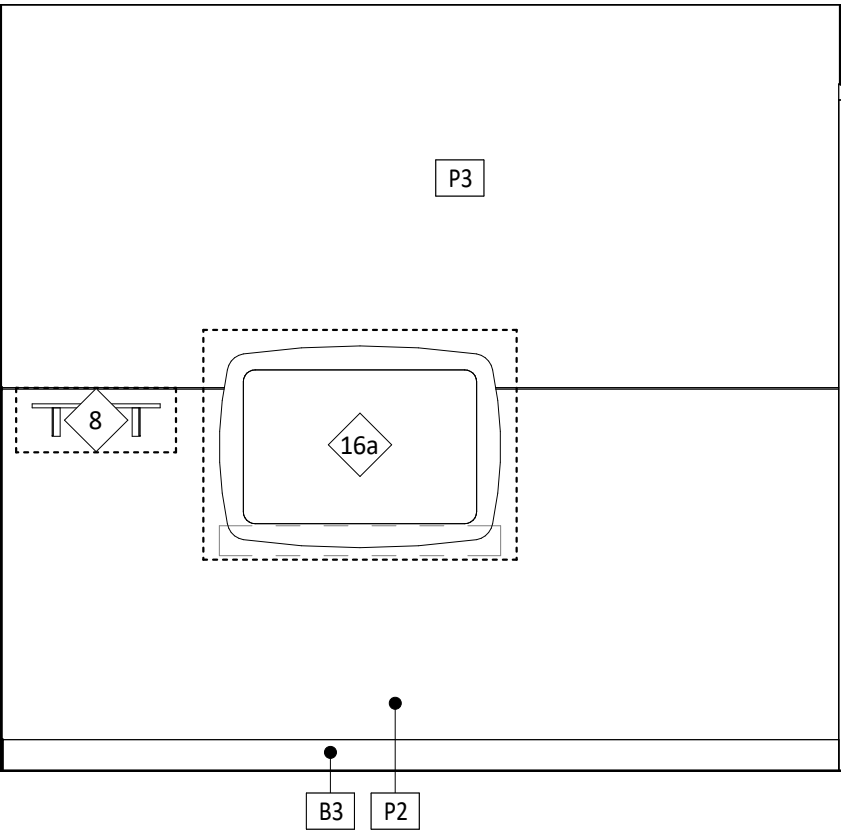


4 UNISEX 1 RESTROOM
SCALE: 1/2" = 1'-0"

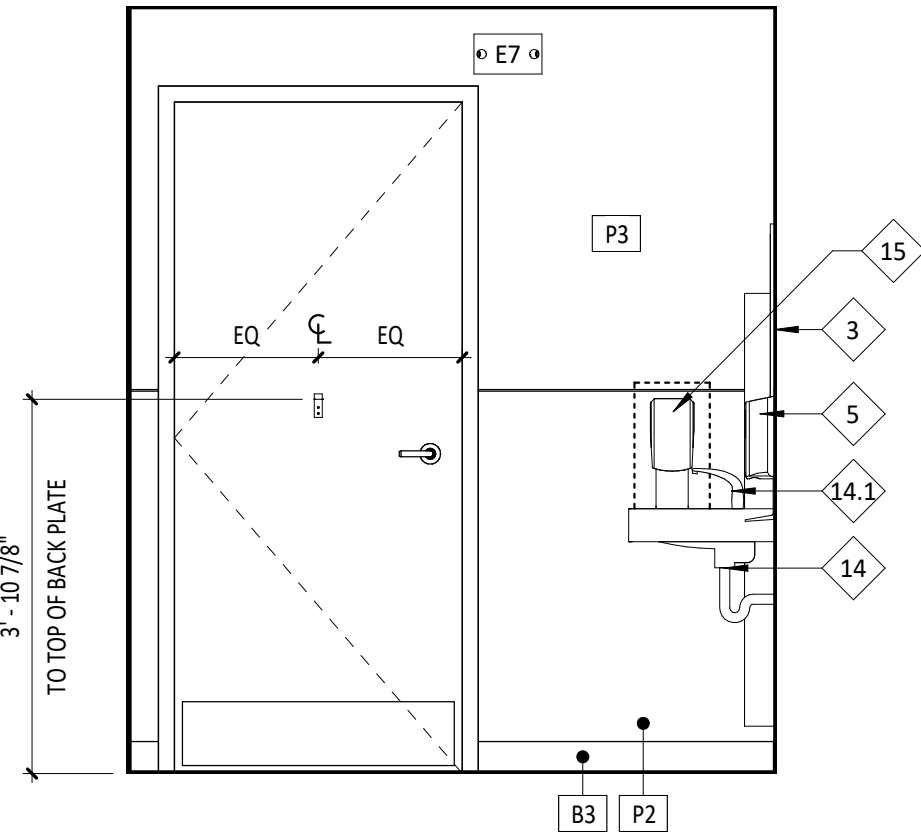


5 UNISEX 1 RESTROOM
SCALE: 1/2" = 1'-0"

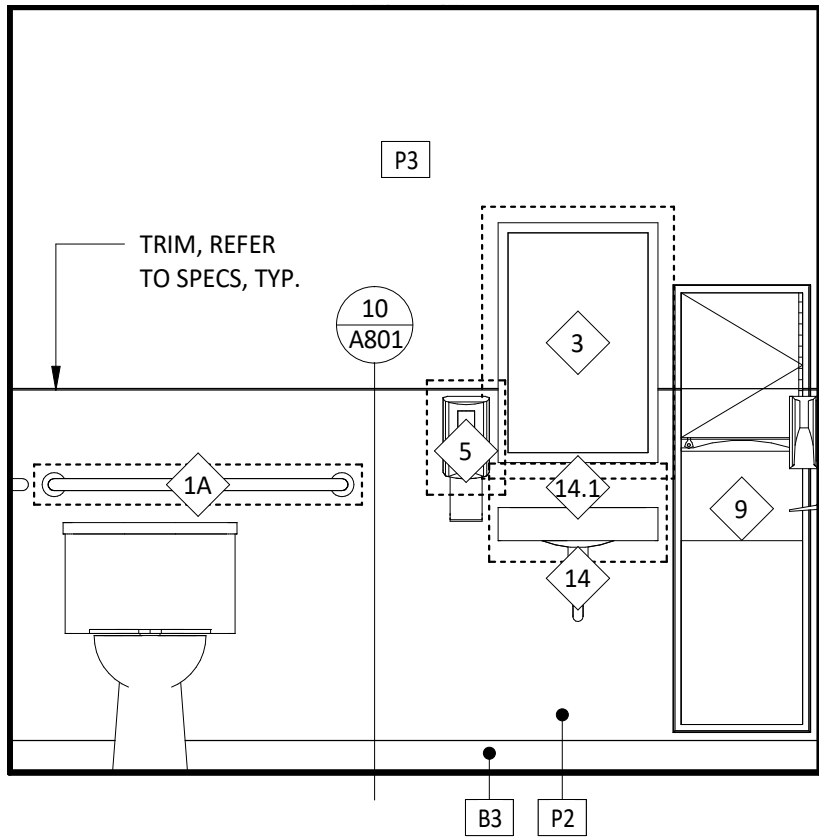


6 UNISEX 2 RESTROOM
SCALE: 1/2" = 1'-0"

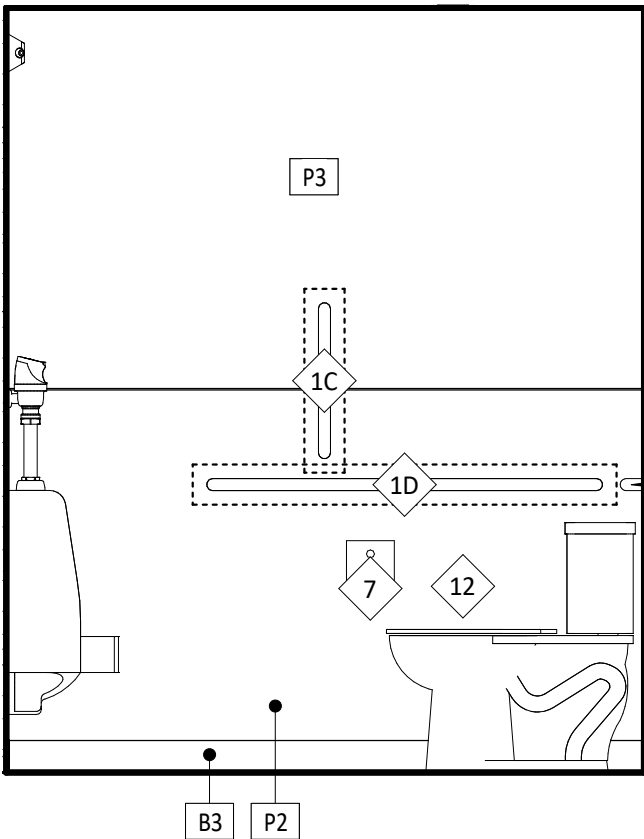


7 UNISEX 2 RESTROOM
SCALE: 1/2" = 1'-0"

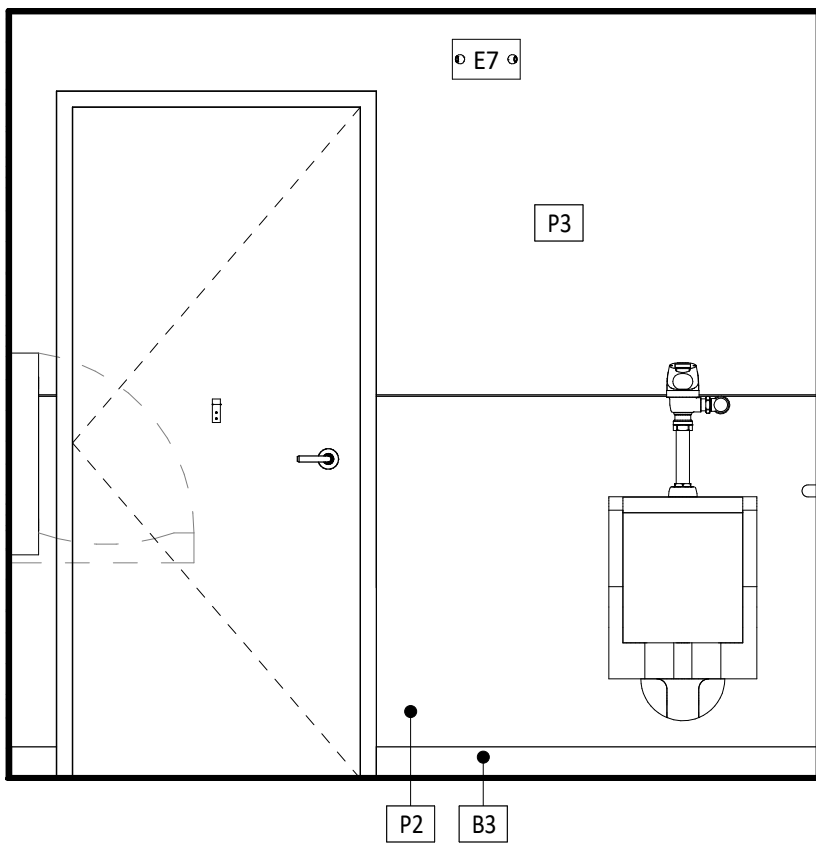







8 UNISEX 2 RESTROOM
SCALE: 1/2" = 1'-0"






















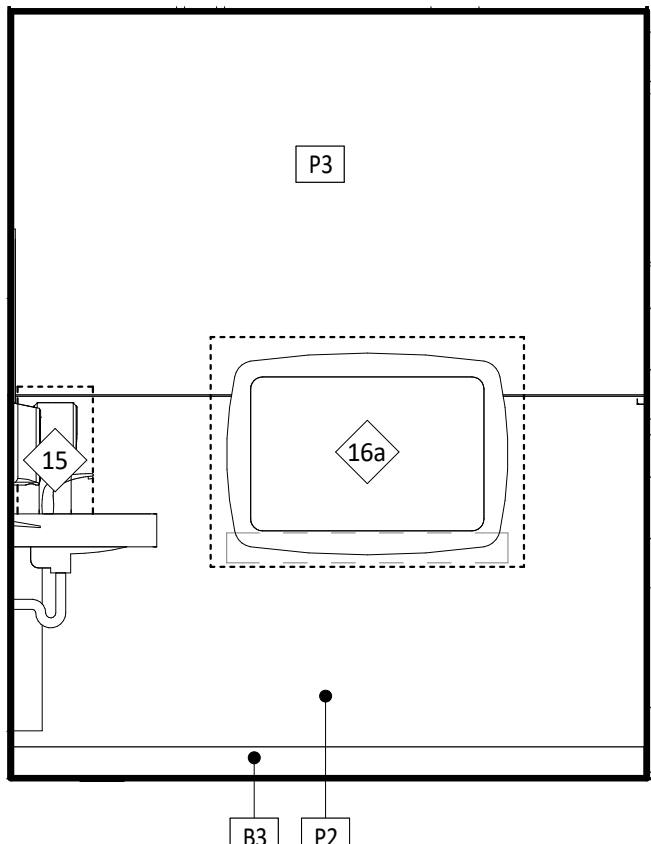














9 UNISEX 2 RESTROOM
SCALE: 1/2" = 1'-0"

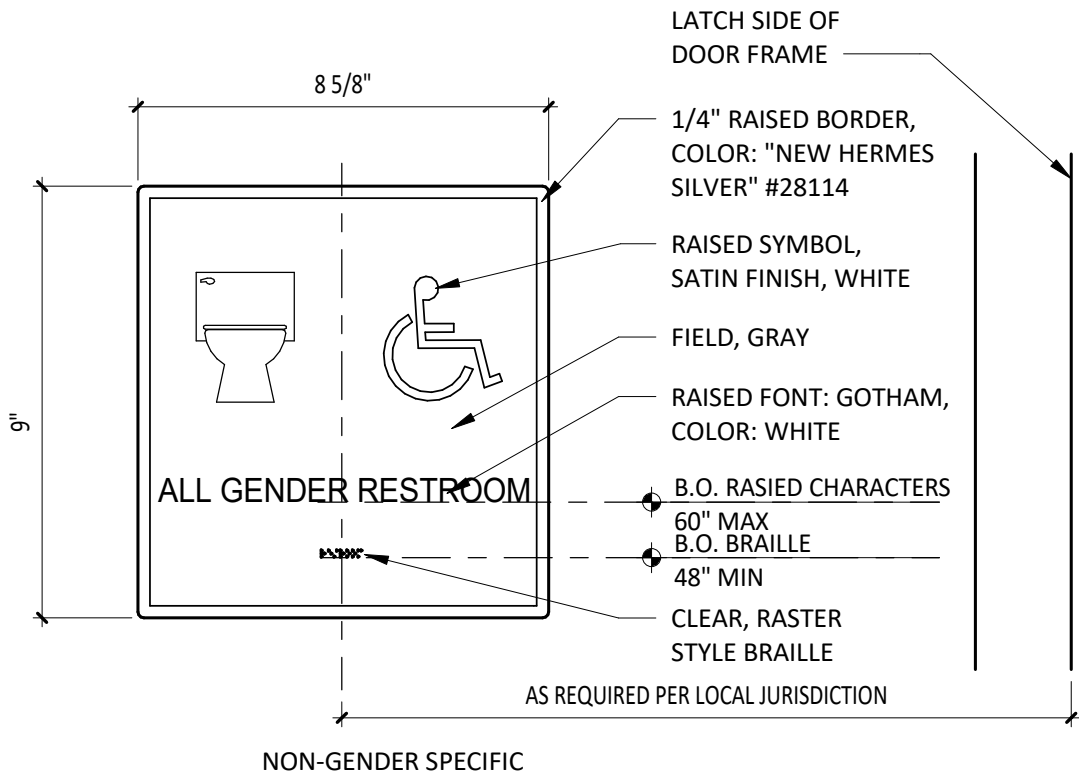

10 TYPICAL RESTROOM SIGNAGE
SCALE: 3" = 1'-0"

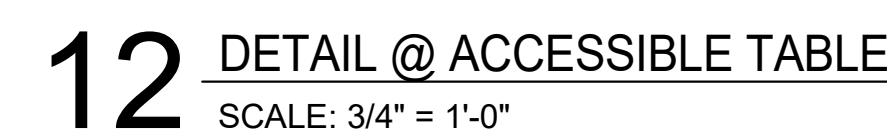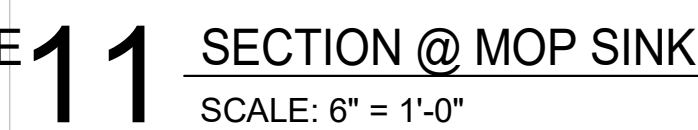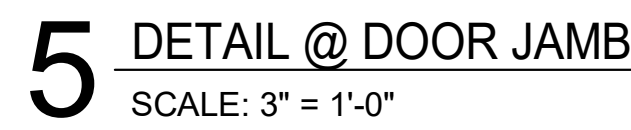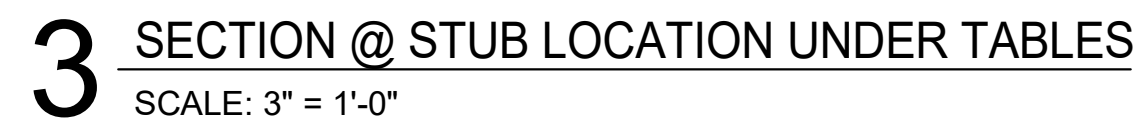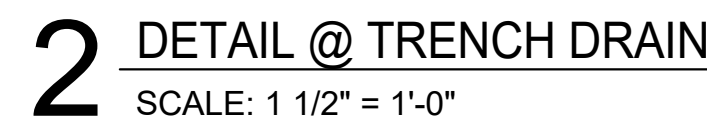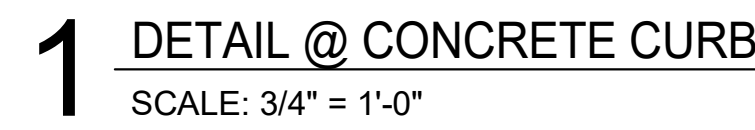

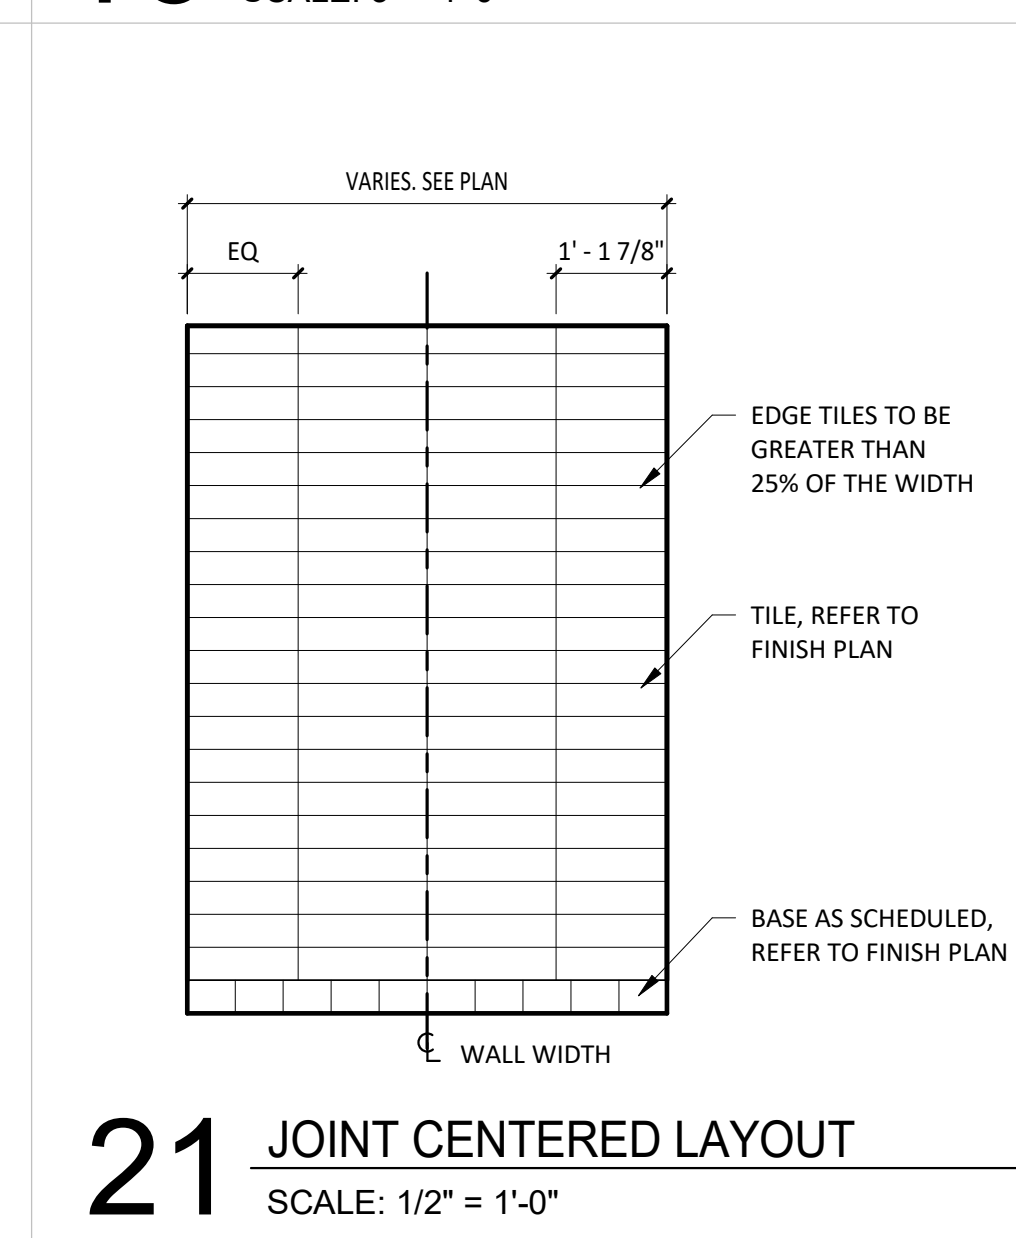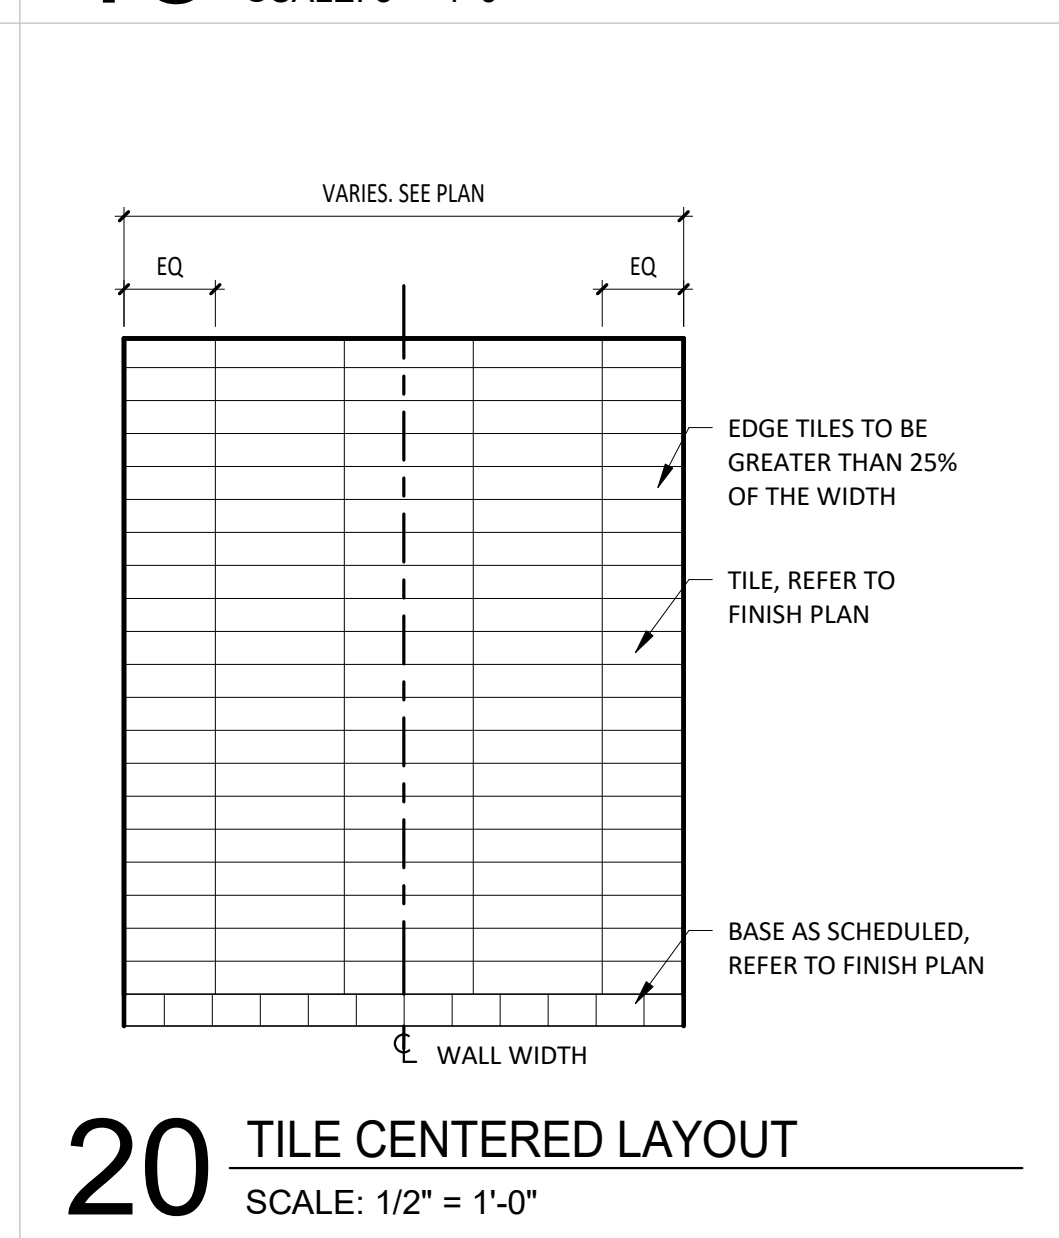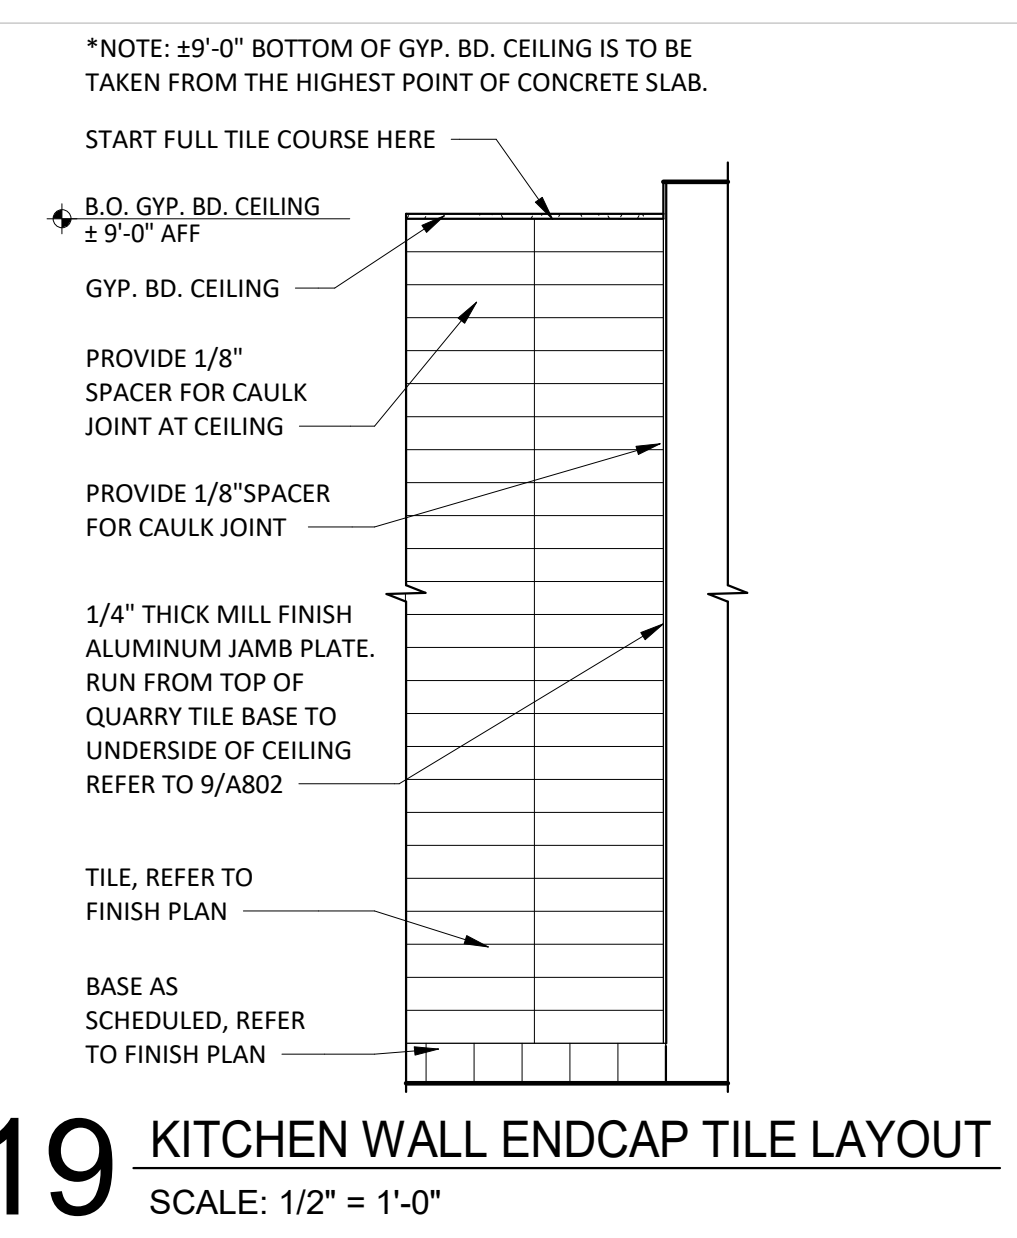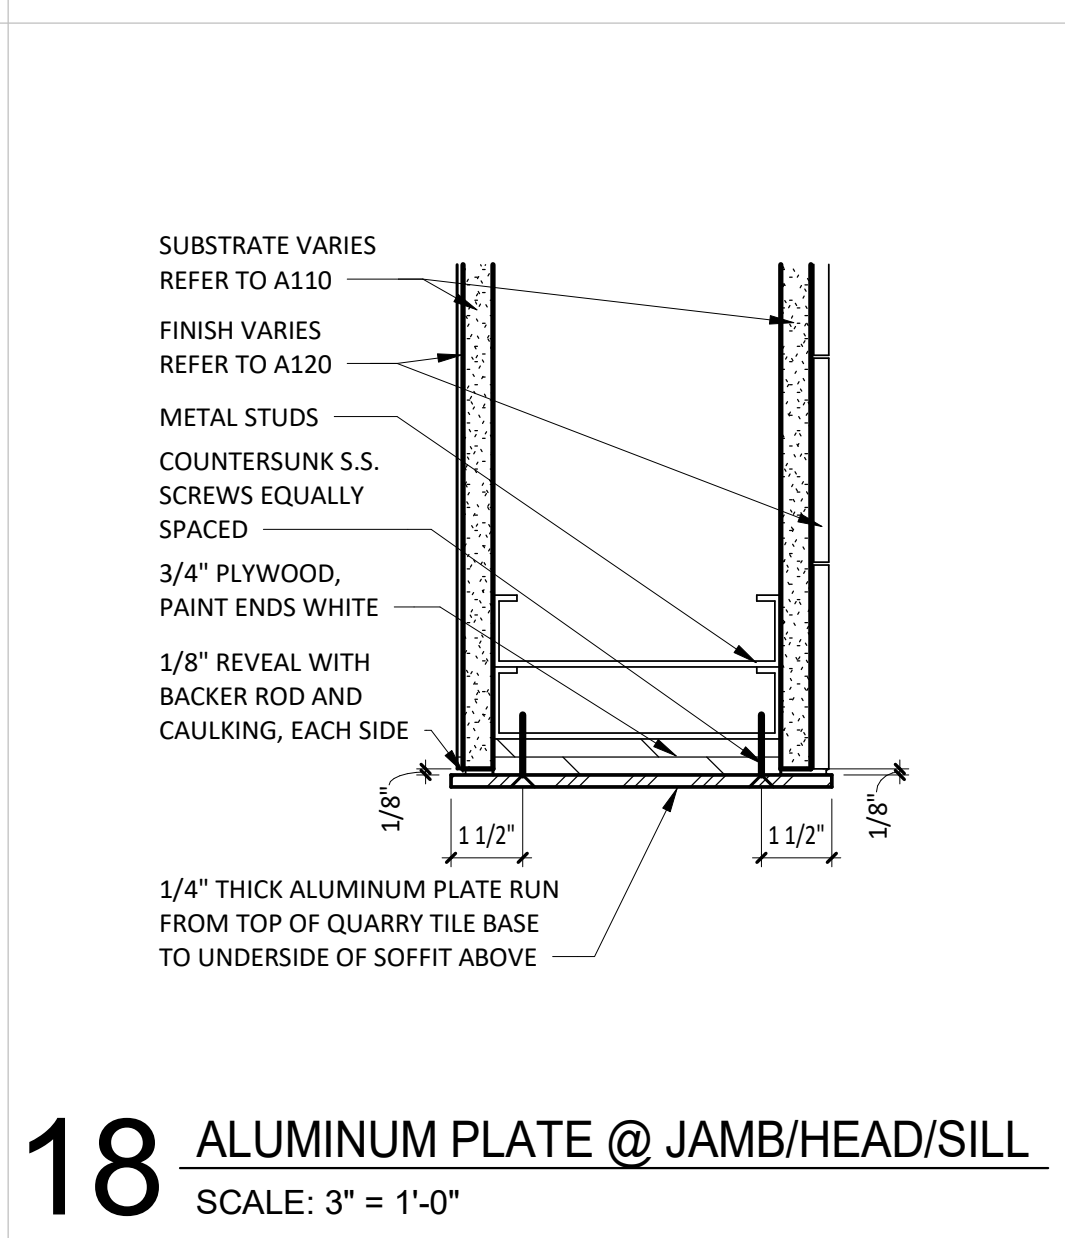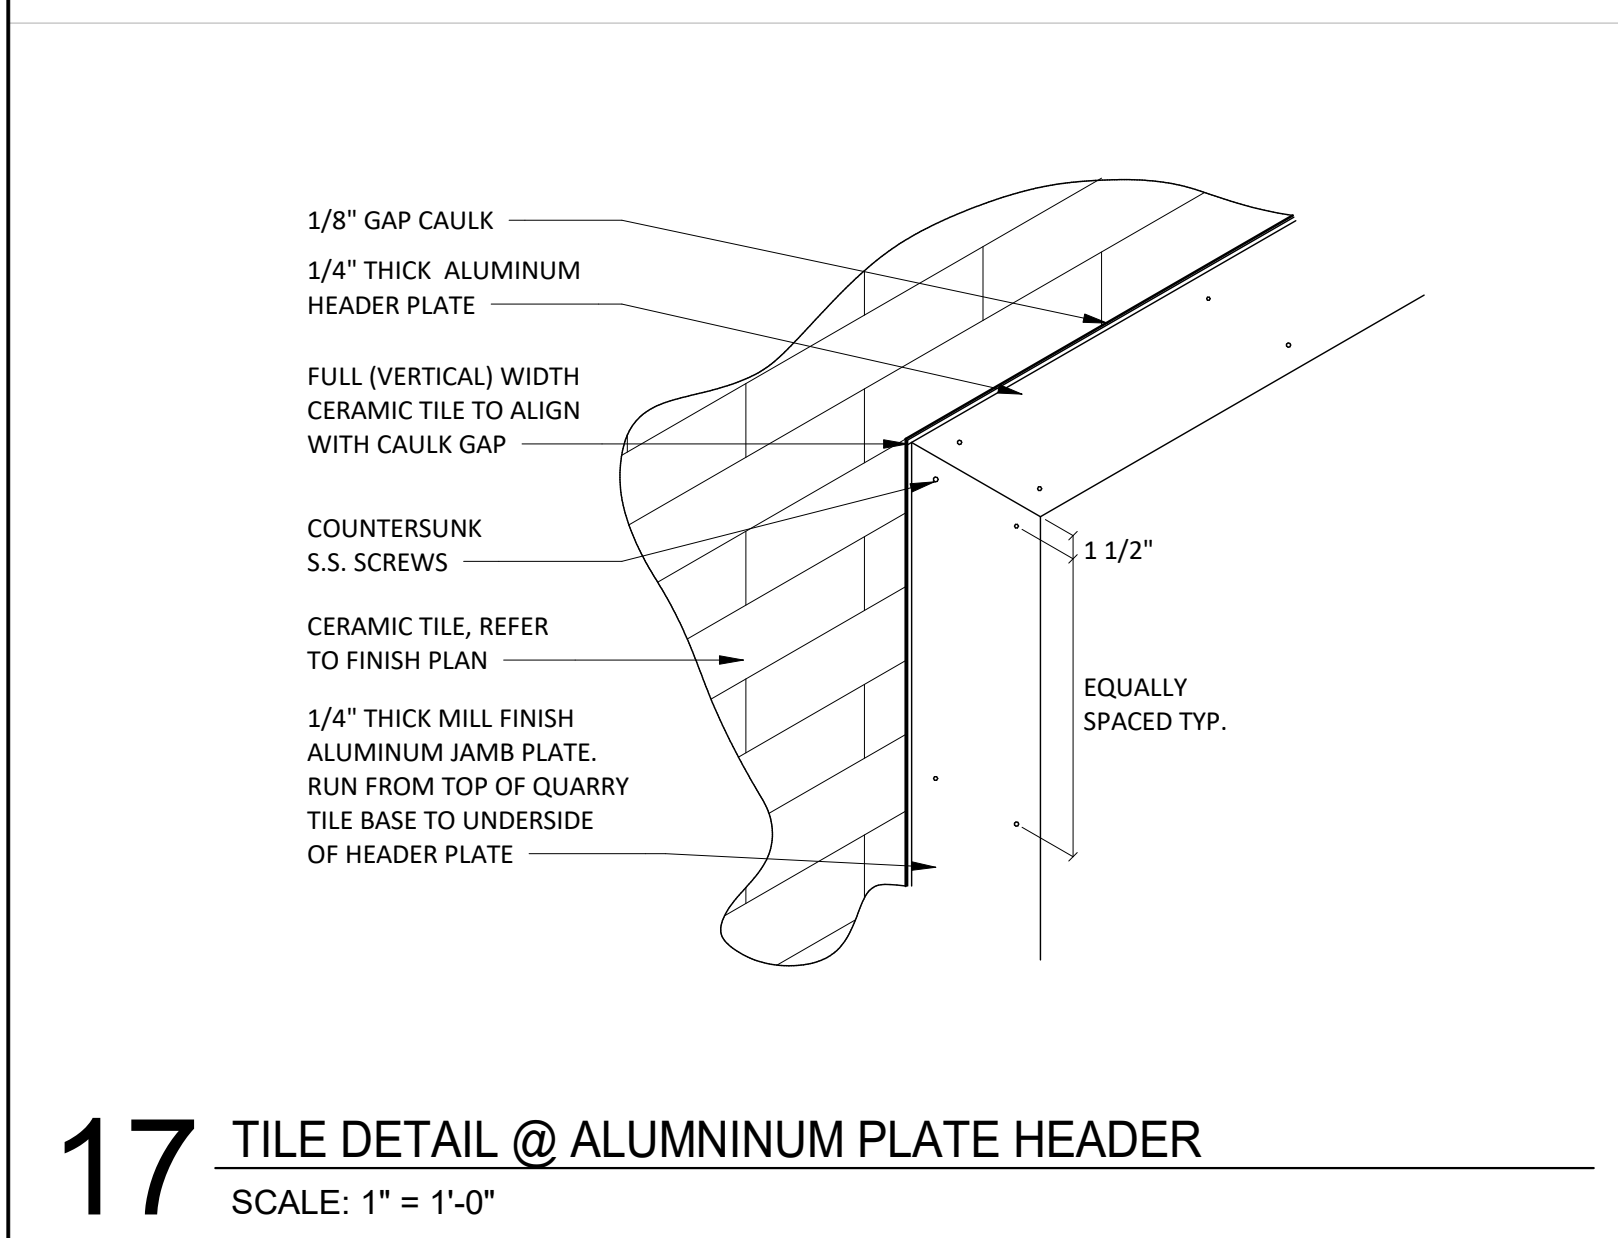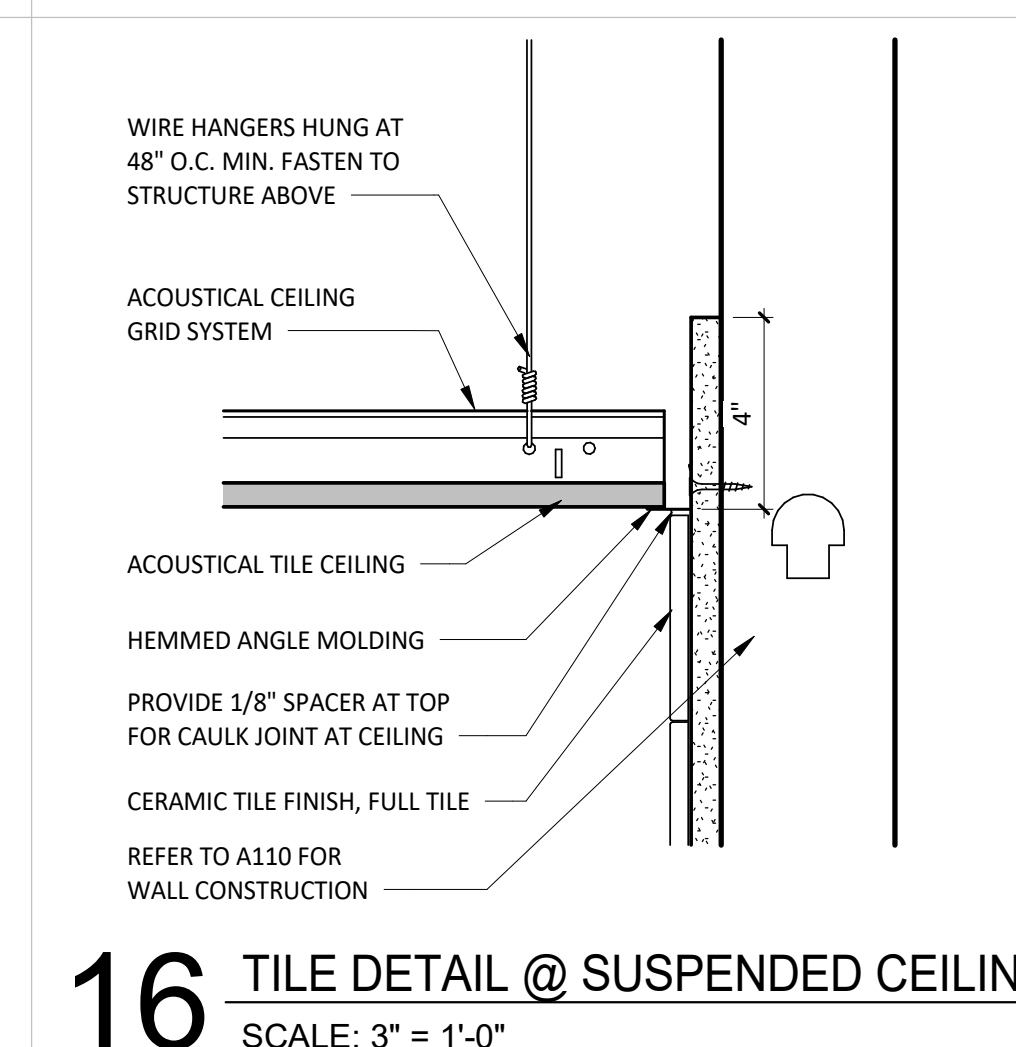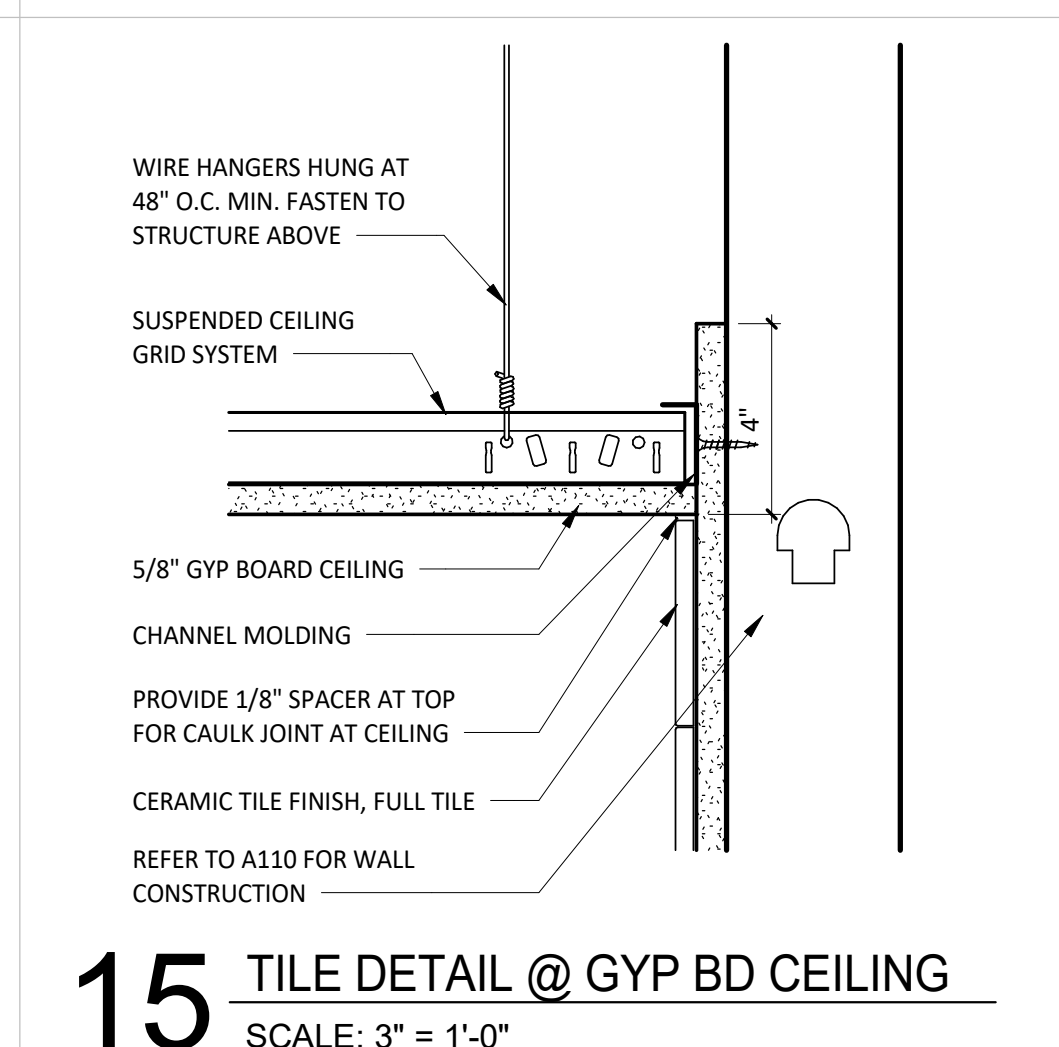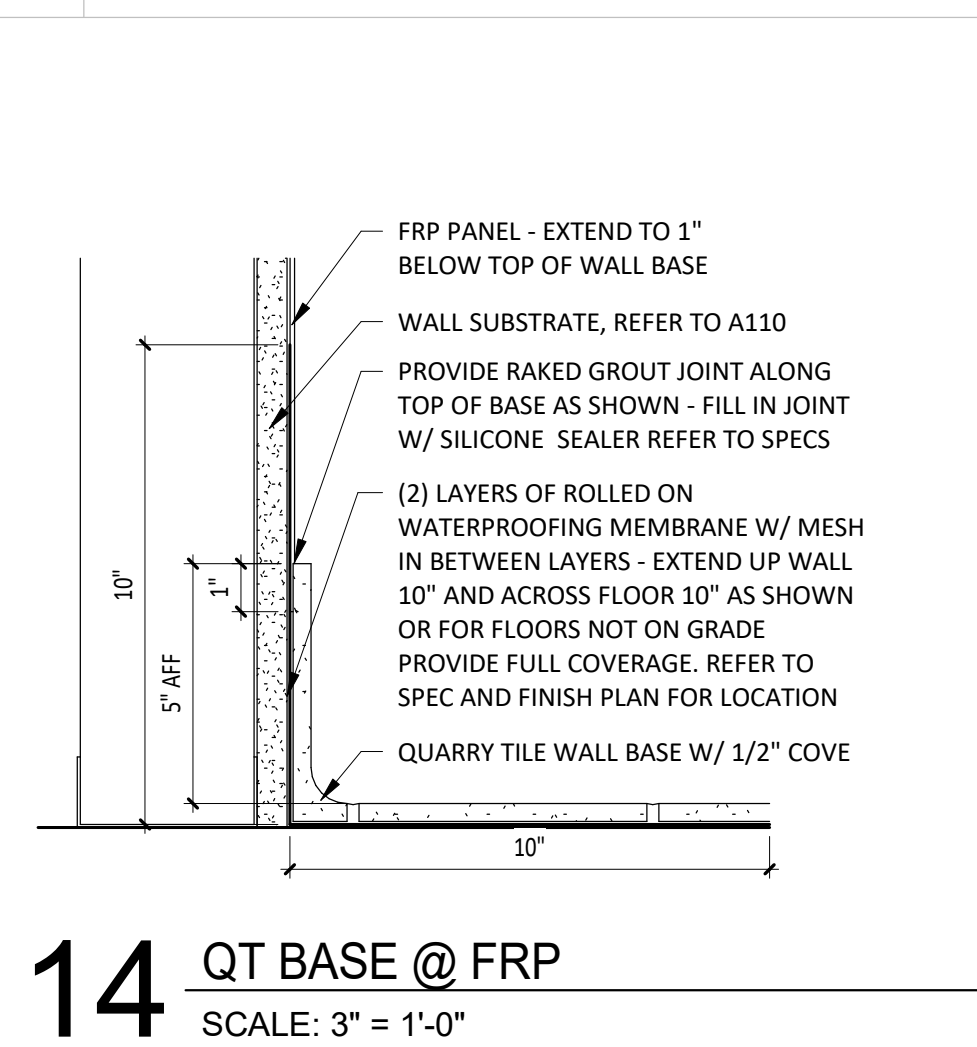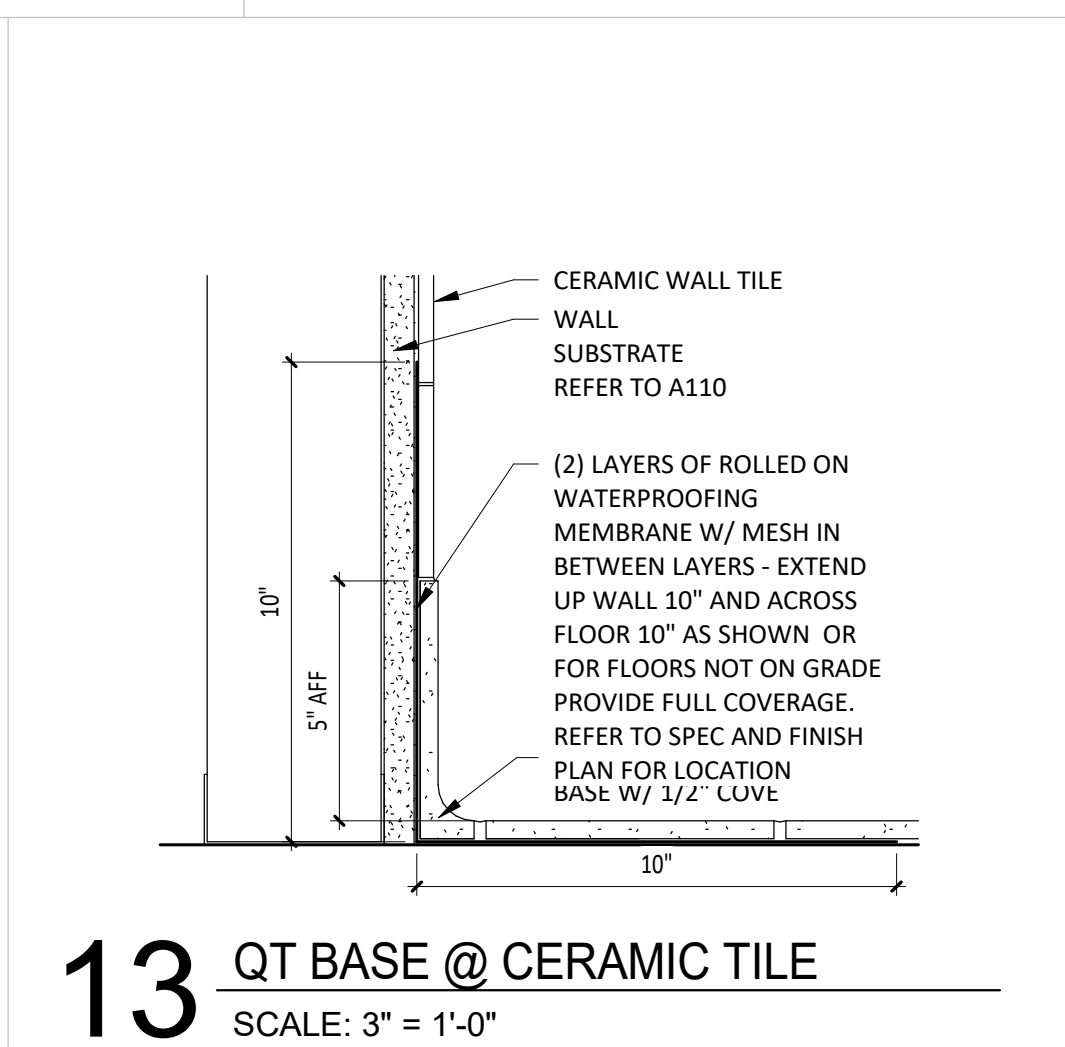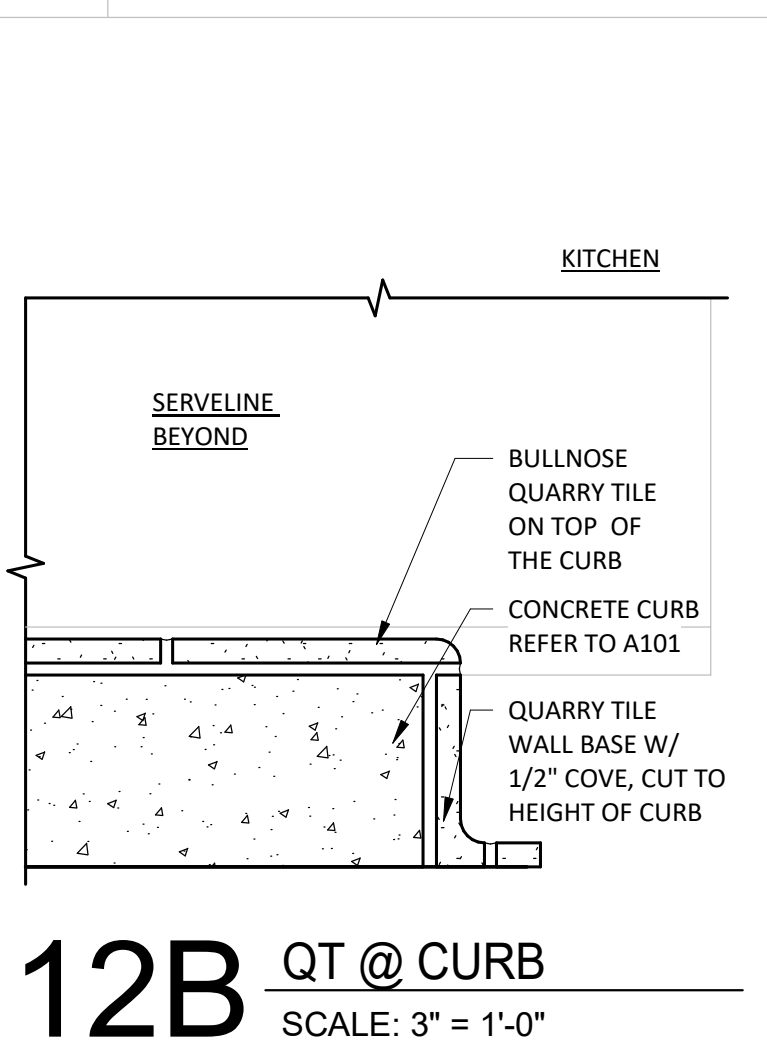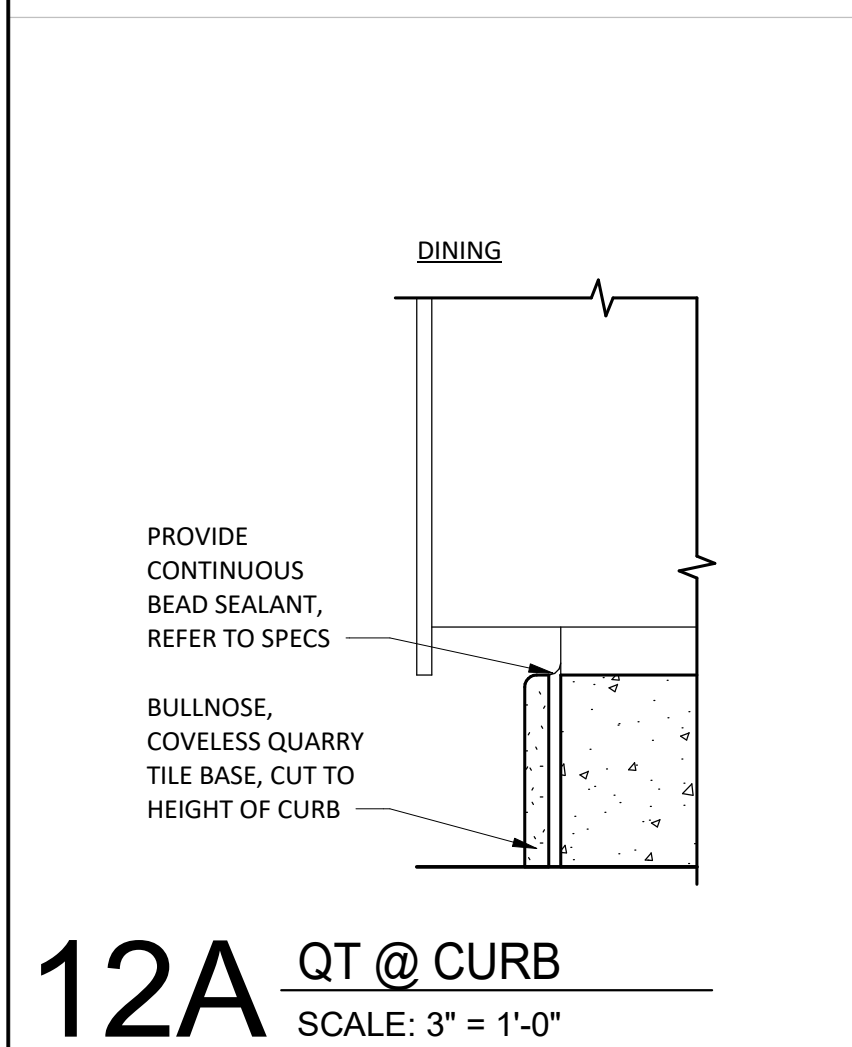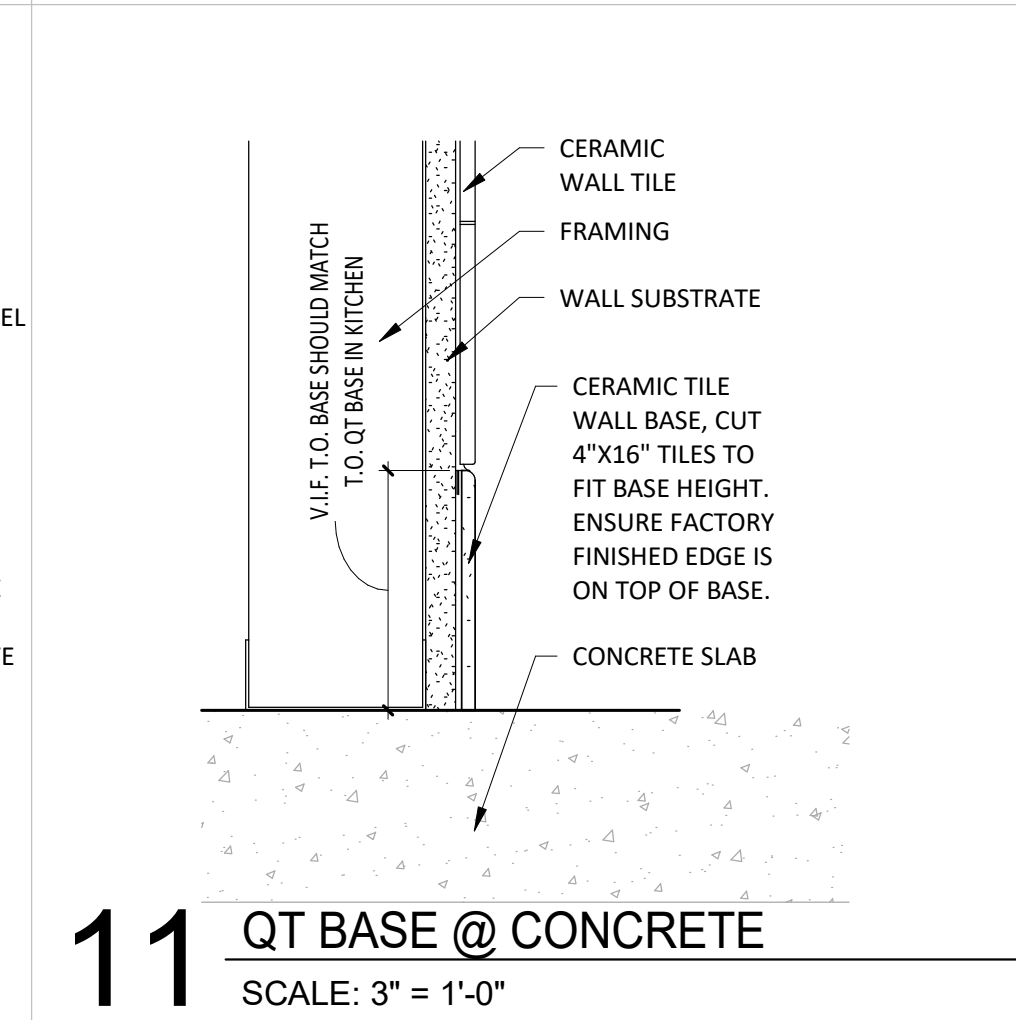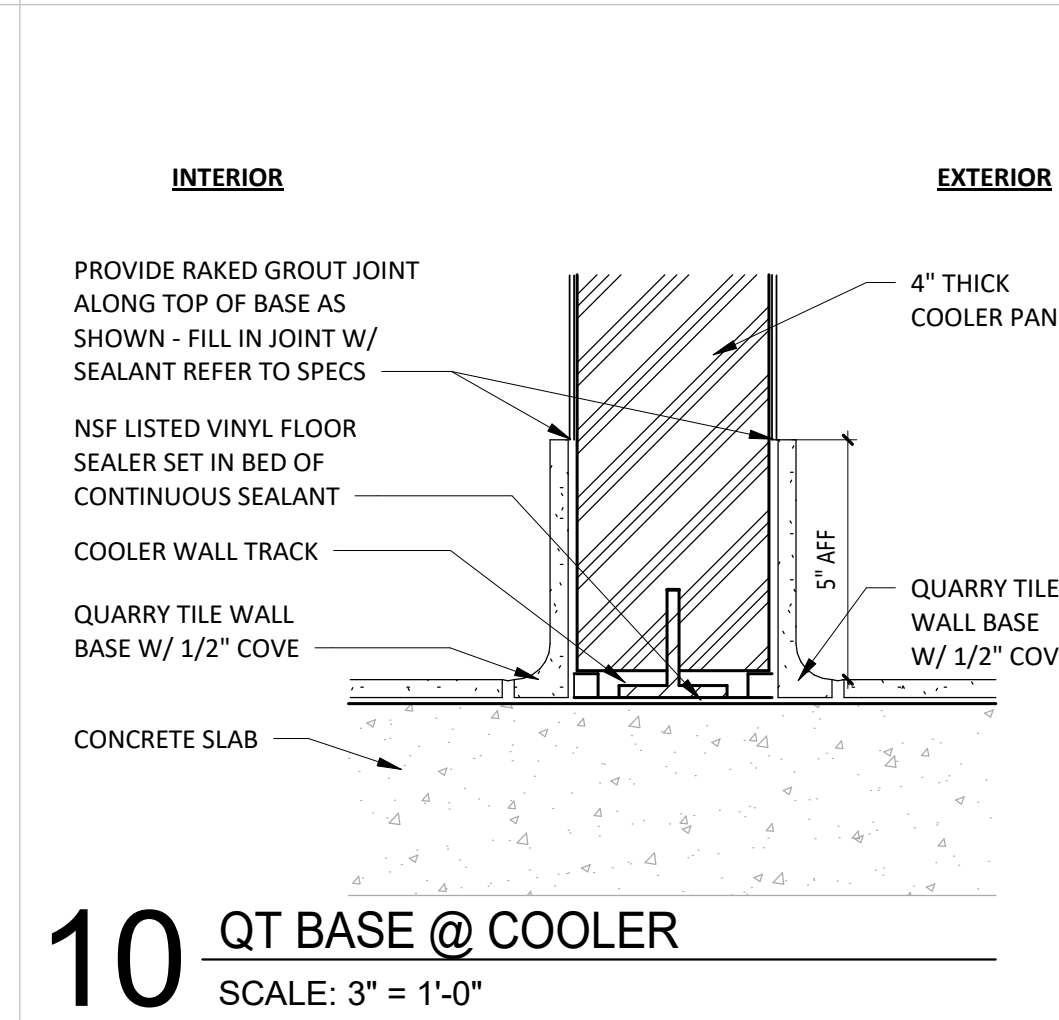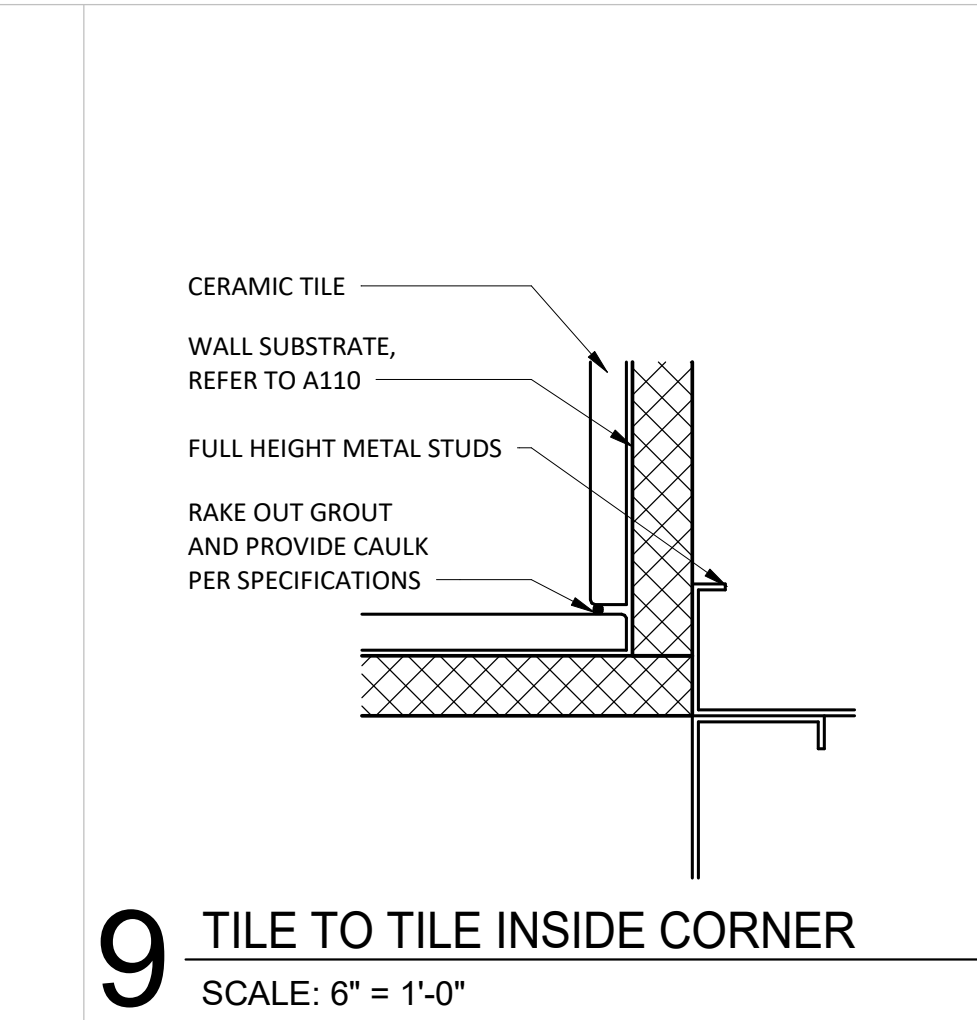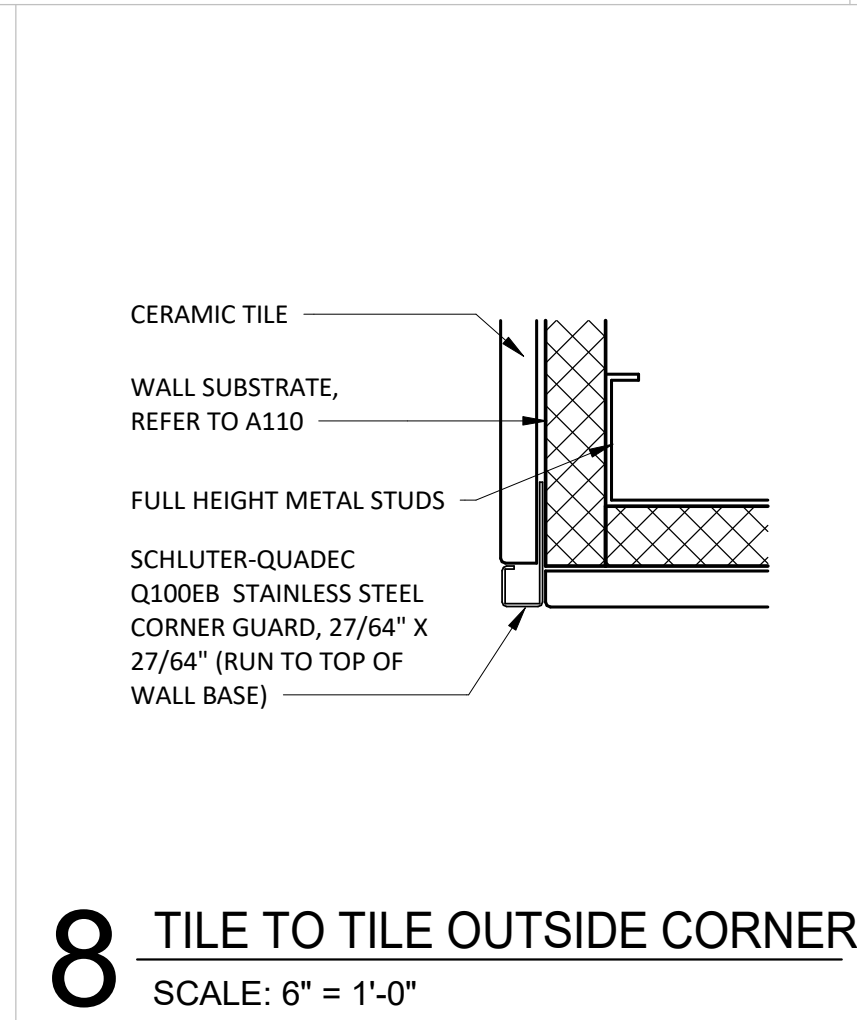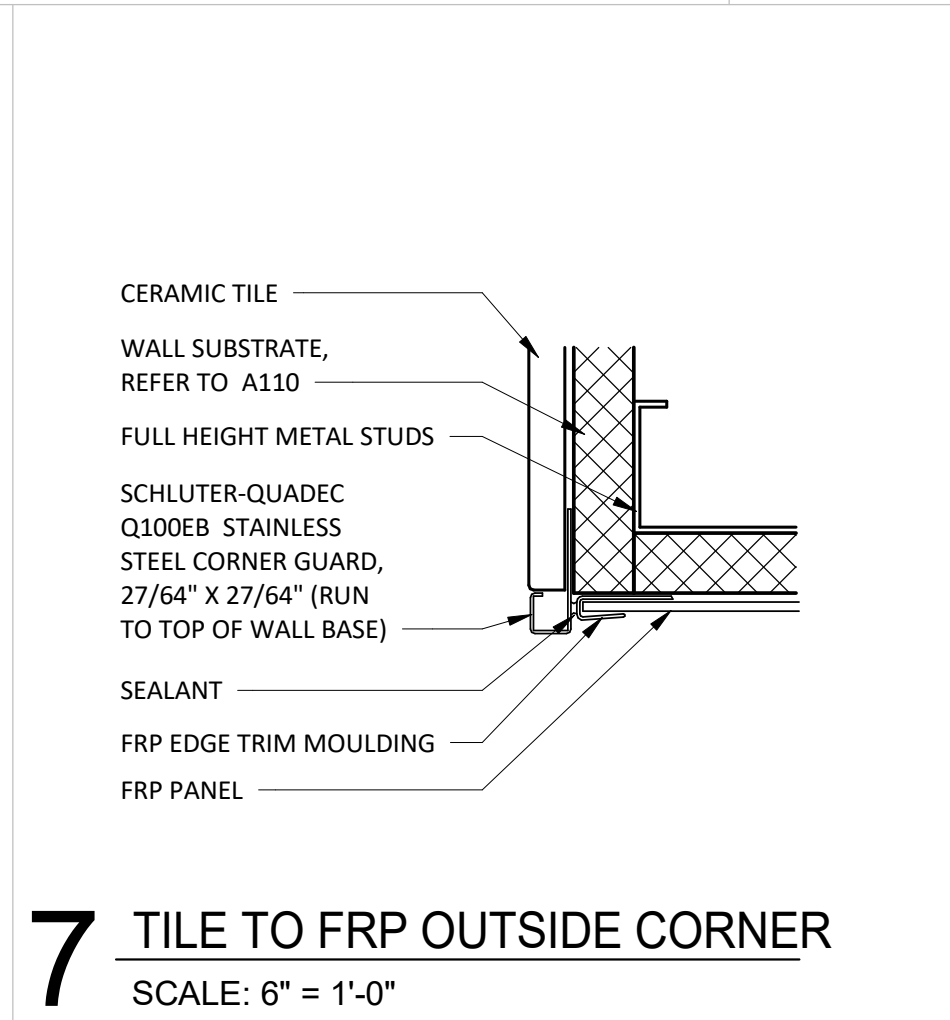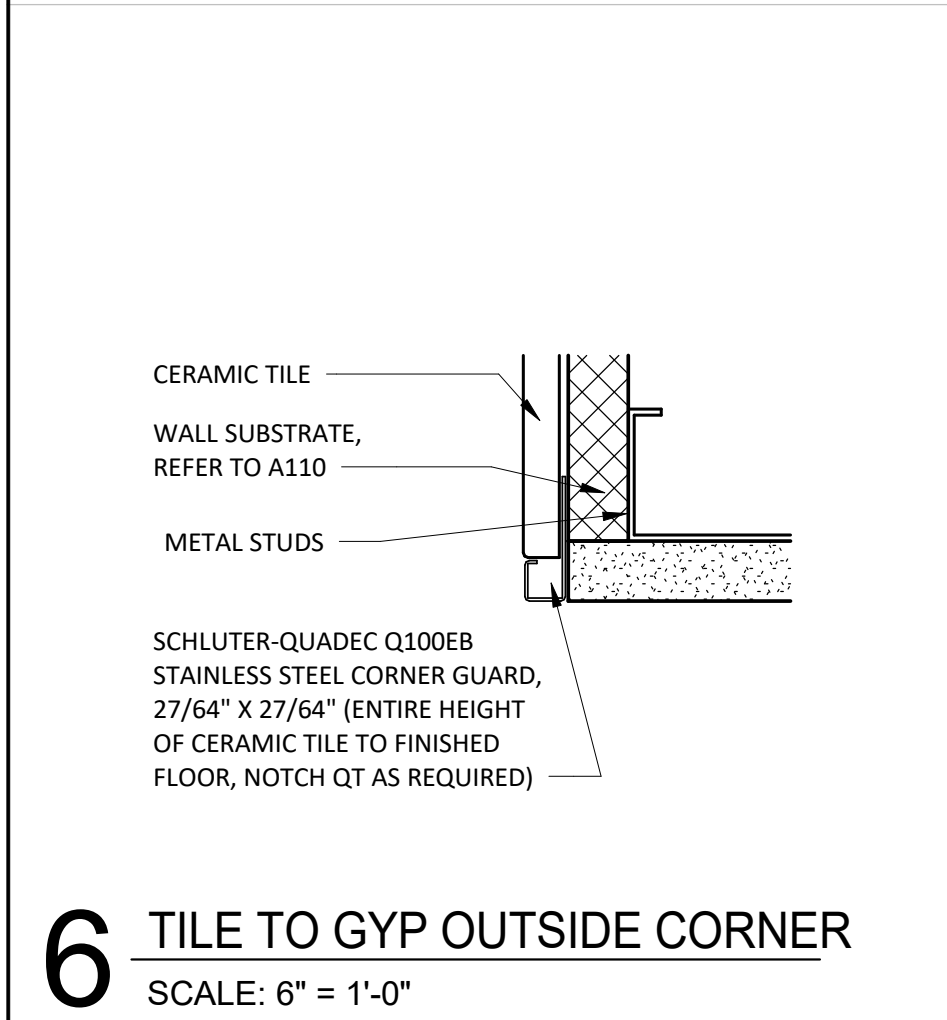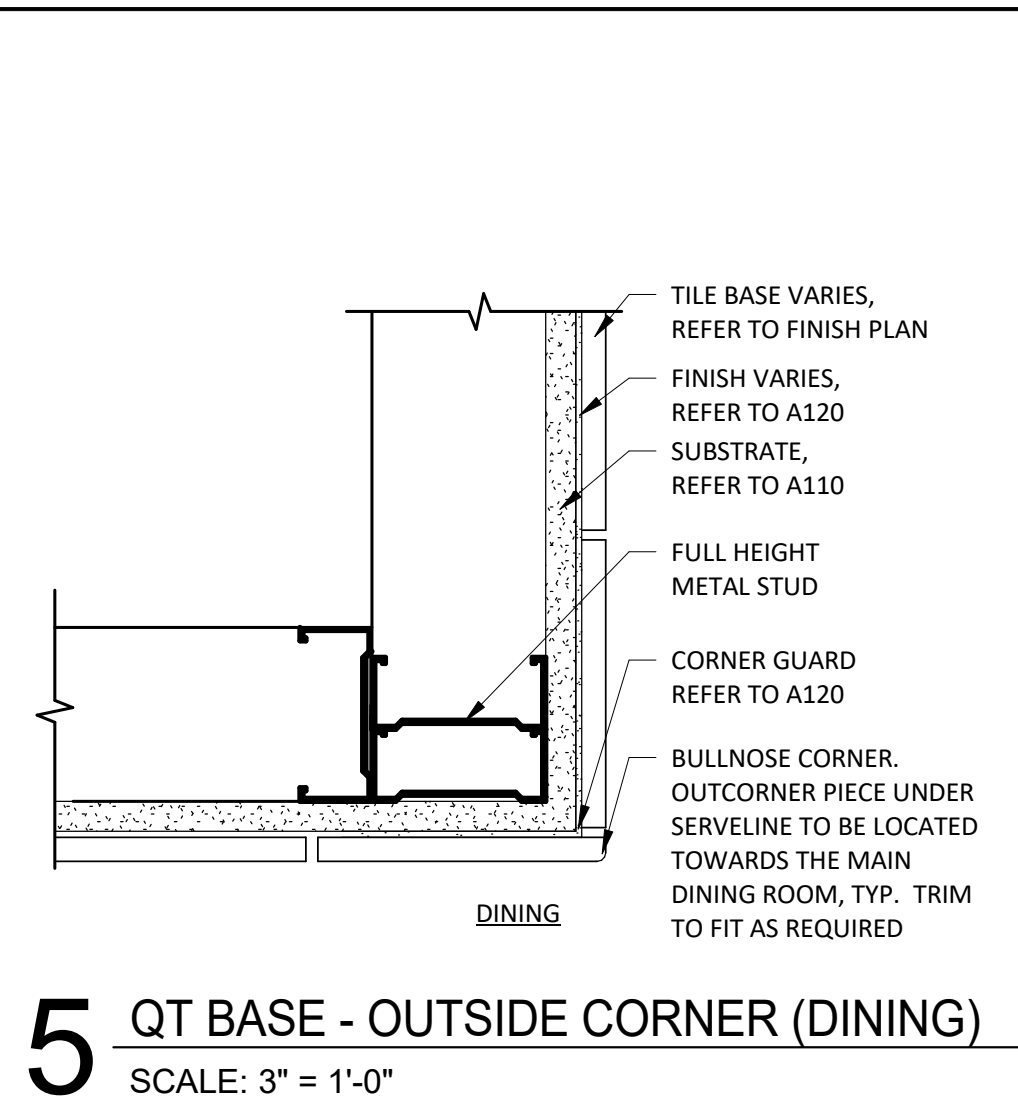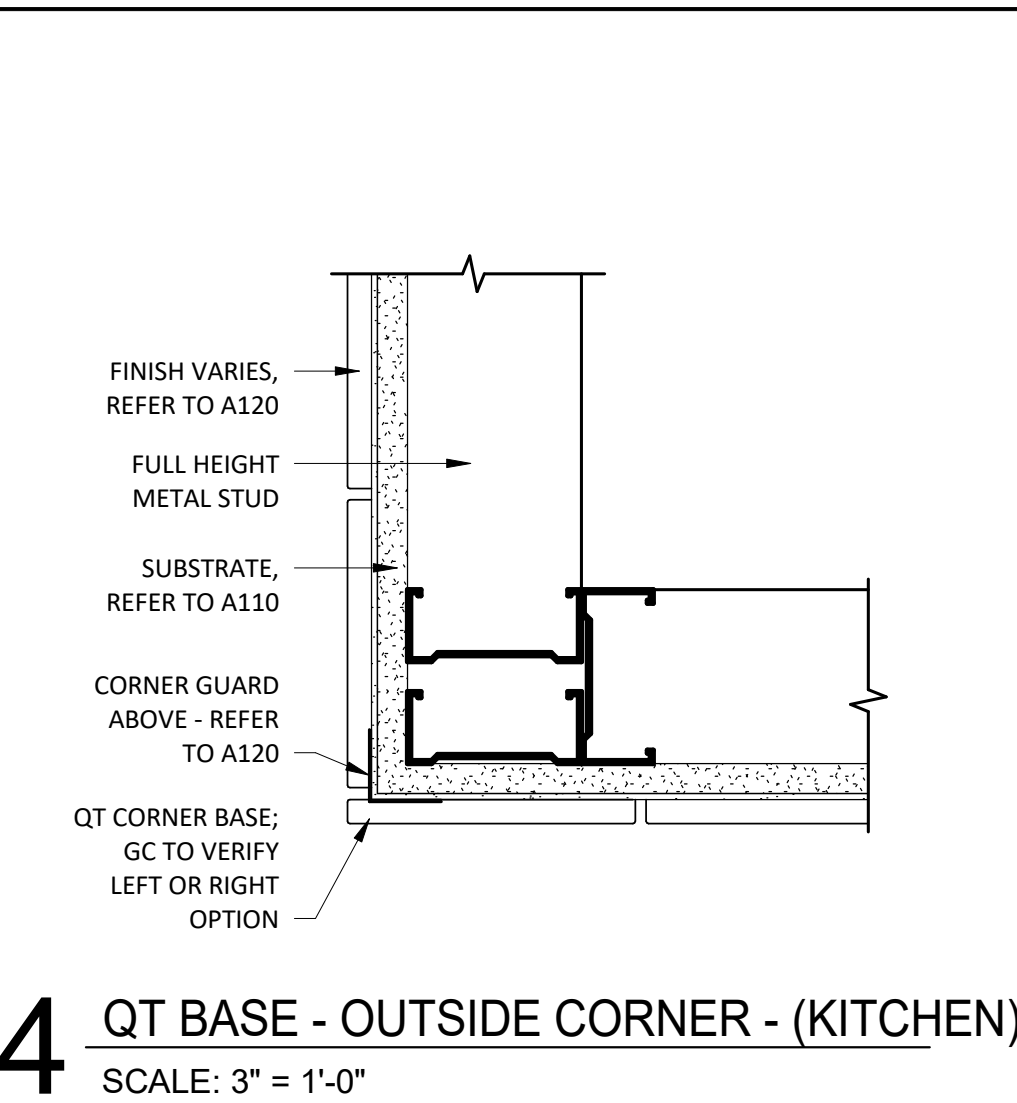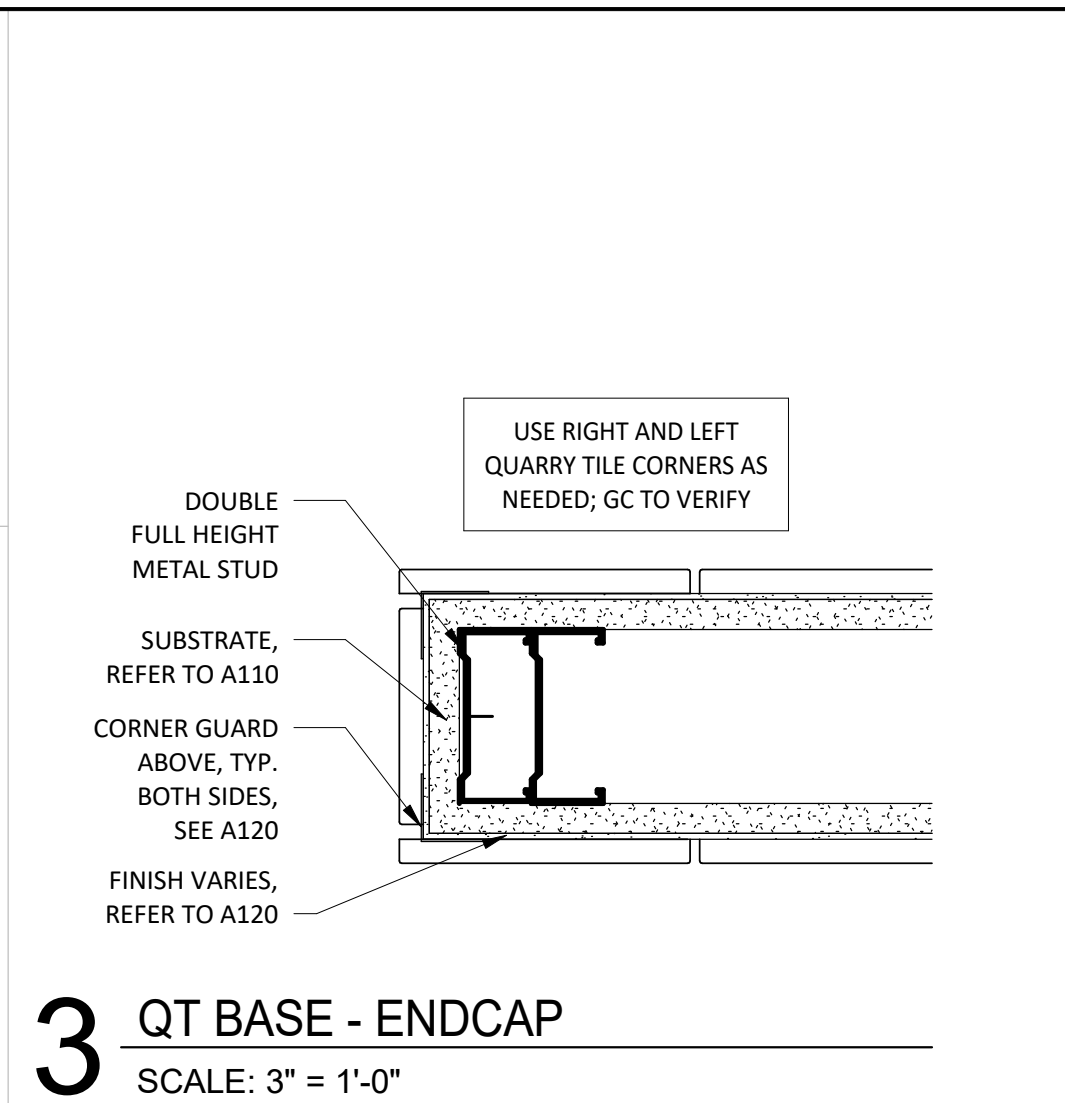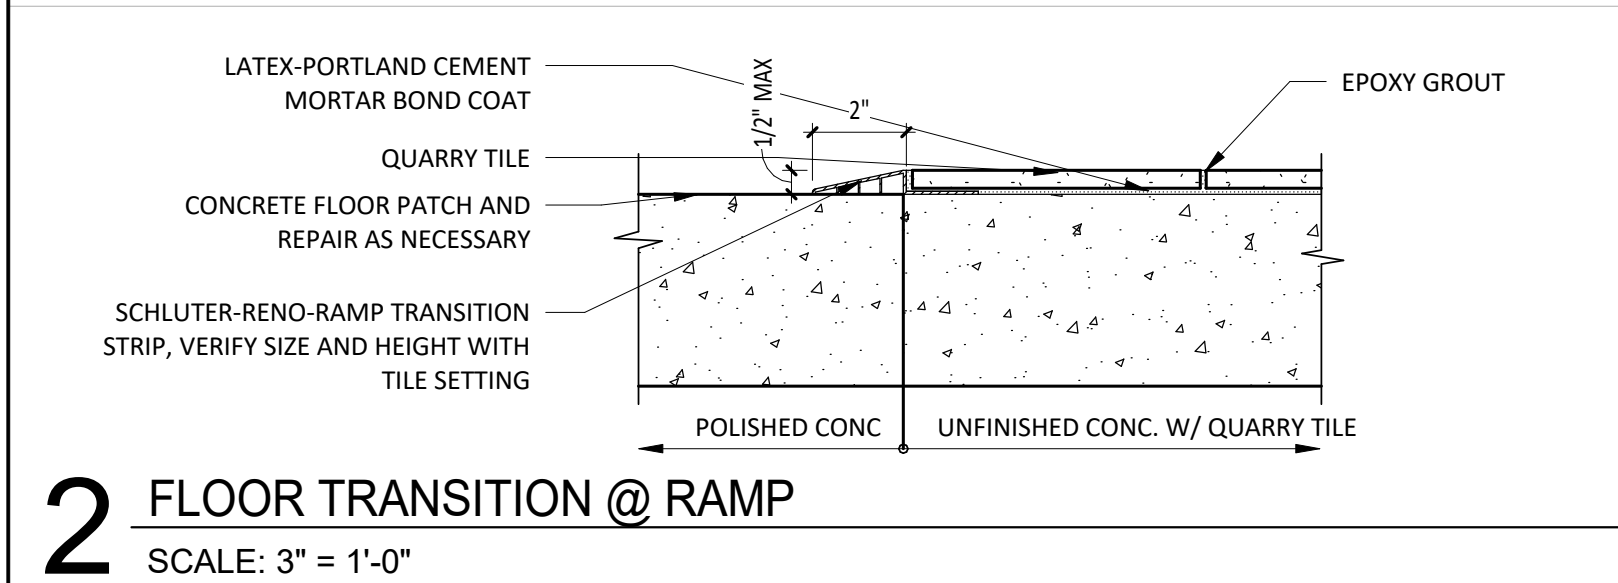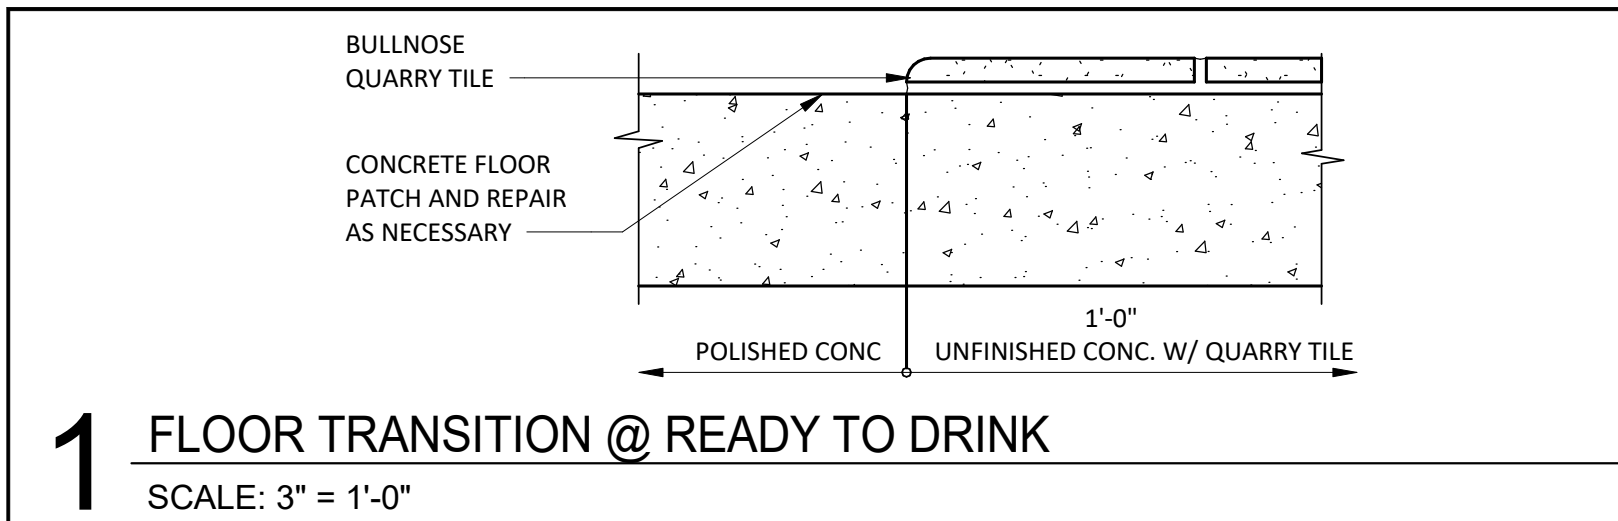

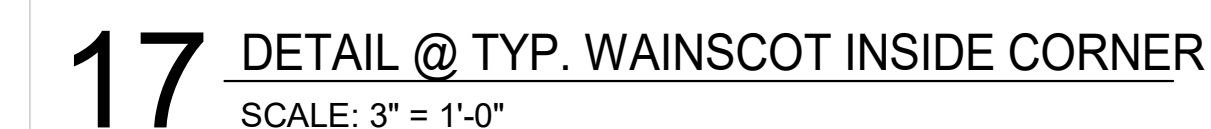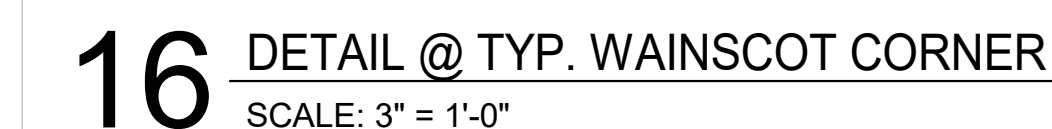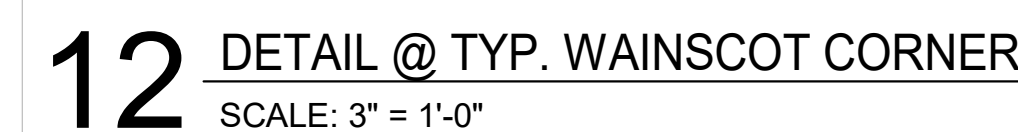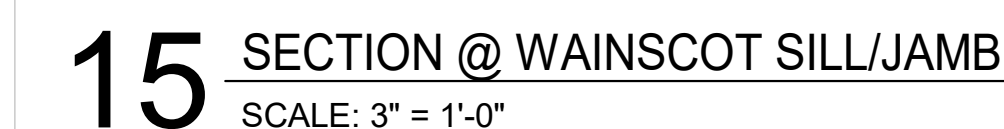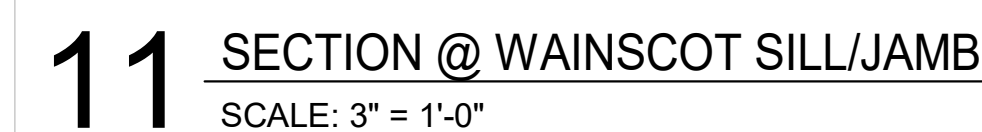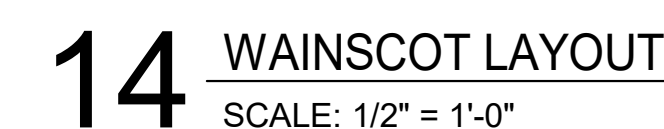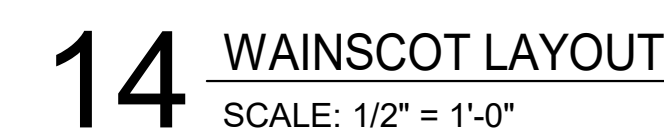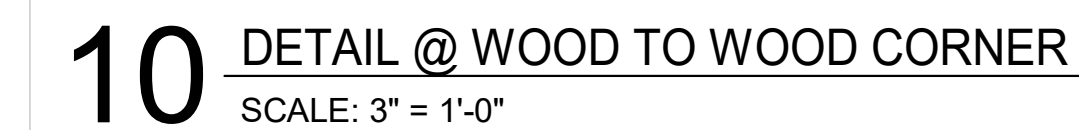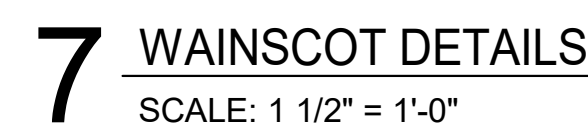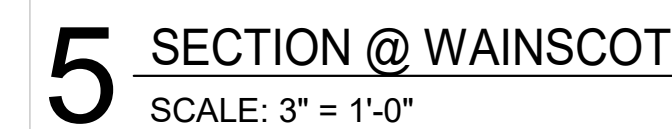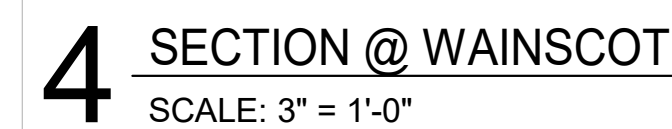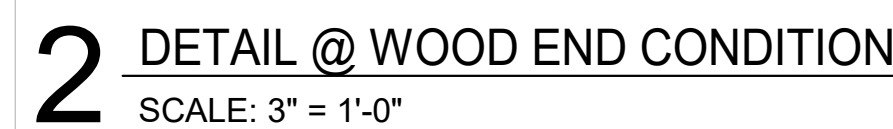

GENERAL STRUCTURAL NOTES

1

BUILDING CODE:

2015 INTERNATIONAL BUILDING CODE (IBC).

2

DESIGN LOADS:

2.1

SHELL ENGINEER TO DETERMINE BUILDING DESIGN LOADS.

2.2

EQUIPMENT:

ROOFTOP UNITS SEE PLAN

3

GENERAL NOTES:

3.1

CONTRACTOR SHALL BE SOLELY RESPONSIBLE FOR THE MEANS AND METHODS OF CONSTRUCTION AND FOR THE SAFETY OF PERSONS AND PROPERTY. CONTRACTOR SHALL BE RESPONSIBLE FOR COMPLYING WITH ALL SAFETY PRECAUTIONS AND REGULATIONS DURING THE WORK. THE ENGINEER WILL NOT ADVISE ON NOR ISSUE DIRECTION AS TO SAFETY PRECAUTIONS AND PROGRAMS.

3.2

THE STRUCTURAL DRAWINGS HEREIN REPRESENT THE FINISHED STRUCTURE. DURING ERECTION OF THE STRUCTURE, THE CONTRACTOR SHALL BE SOLELY RESPONSIBLE FOR TEMPORARY GUYING, SHORING, BRACING, FORMING, ETC. SUCH MEASURES SHALL BE LEFT IN PLACE AS LONG AS REQUIRED FOR SAFETY AND UNTIL ALL FRAMING AND CONNECTIONS ARE IN PLACE. THE INVESTIGATION, DESIGN, SAFETY, ADEQUACY AND INSPECTION OF SUCH TEMPORARY MEASURES ARE THE SOLE RESPONSIBILITY OF THE CONTRACTOR.

3.3

DRAWINGS INDICATE GENERAL AND TYPICAL DETAILS OF CONSTRUCTION, WHERE CONDITIONS ARE NOT SPECIFICALLY SHOWN, SIMILAR DETAILS OF CONSTRUCTION SHALL BE USED, SUBJECT TO REVIEW BY THE ENGINEER.

3.4

ARCHITECTURAL DRAWINGS, MECHANICAL DRAWINGS, ELECTRICAL DRAWINGS, TELECOMMUNICATION DRAWINGS, FIRE PROTECTION DRAWINGS, EQUIPMENT DRAWINGS AND RELATED ITEMS ARE BY OTHERS.

3.5

CONTRACTOR AND SUBCONTRACTORS SHALL THOROUGHLY REVIEW ALL DRAWINGS PRIOR TO SUBMITTING BIDS. MISCELLANEOUS FASTENERS, CLIPS, ETC. THAT ARE NOT DETAILED ON THE DRAWINGS BUT ARE PART OF THE REQUIREMENTS FOR FULL INSTALLATION OF ALL STRUCTURAL SYSTEMS ARE TO BE PART OF THE BID. THE CONTRACTOR SHALL VISIT THE SITE PRIOR TO THE BID TO ASCERTAIN CONDITIONS WHICH MAY ADVERSELY AFFECT THE BID.

3.6

DURING THE BIDDING STAGE, CONTRACTOR SHALL REQUEST AN INTERPRETATION OF CONFLICTS PRIOR TO BIDDING. IF NO REQUEST IS MADE, BOTH PROVISIONS SHALL BE PRESUMED TO BE INCLUDED IN THE BID AND THE ARCHITECT/ENGINEER SHALL DETERMINE WHICH PROVISION GOVERNS, AND THE CONTRACTOR SHALL PERFORM THE WORK AT NO ADDITIONAL COST TO THE OWNER.

3.7

ALL OMISSIONS AND CONFLICTS BETWEEN THE VARIOUS ELEMENTS OF THE CONSTRUCTION DRAWINGS AND/OR SPECIFICATIONS AND/OR EXISTING CONDITIONS SHALL BE BROUGHT TO THE ATTENTION OF THE ENGINEER BEFORE PROCEEDING WITH THE WORK.

3.8

THE CONTRACTOR SHALL COORDINATE ALL DEPRESSIONS, DIMENSIONS, ELEVATIONS, SLEEVES, CHASES, HANGERS, OPENINGS, BLOCK OUTS, INSERTS, ANCHORS, EQUIPMENT SUPPORTS, AND DETAILS WITH THE ENTIRE CONSTRUCTION PACKAGE INCLUDING ARCHITECTURAL DRAWINGS, MECHANICAL DRAWINGS, ELECTRICAL DRAWINGS, TELECOMMUNICATION DRAWINGS, FIRE PROTECTION DRAWINGS AND EQUIPMENT DRAWINGS.

3.9

MECHANICAL UNITS SUPPORTED BY ROOF STRUCTURE ARE SUBJECT TO THE ACCEPTANCE OF THE STRUCTURAL ENGINEER.

3.10

DO NOT HANG ANYTHING FROM THE ROOF DECK.

4

EXISTING CONSTRUCTION:

4.1

WHEREVER APPLICABLE, PRIOR TO FABRICATION AND CONSTRUCTION, CONTRACTOR SHALL FIELD VERIFY ALL EXISTING ELEVATIONS, DIMENSIONS, DETAILS OF EXISTING STRUCTURAL CONNECTIONS AND OTHER CONDITIONS WHERE THEY AFFECT THIS CONSTRUCTION; NOTIFY THE ENGINEER IF THERE ARE ANY DEVIATIONS FROM THE CONTRACT DOCUMENTS. CONSULT WITH THE STRUCTURAL ENGINEER BEFORE MAKING ANY MODIFICATIONS TO THE EXISTING STRUCTURE NOT INDICATED ON THE CONTRACT DOCUMENTS.

4.2

BEFORE PROCEEDING WITH ANY WORK WITHIN THE EXISTING FACILITY, THE CONTRACTOR SHALL BECOME FAMILIAR WITH THE EXISTING STRUCTURE. IT SHALL BE THE CONTRACTOR'S RESPONSIBILITY TO PROVIDE ALL NECESSARY BRACING, SHORING AND OTHER SAFEGUARDS TO MAINTAIN ALL PARTS OF THE EXISTING WORK IN A SAFE CONDITION DURING THE PROCESS OF DEMOLITION AND CONSTRUCTION AND TO PROTECT FROM DAMAGE THOSE PORTIONS OF THE EXISTING WORK WHICH ARE TO REMAIN.

4.3

THE CONTRACTOR SHALL CONSIDER ALL HAZARDS DUE TO WELDING WITHIN THE EXISTING FACILITY, INCLUDING FIRE HAZARD, TOXIC SMOKE HAZARD AND LIQUEFAS UNDER LOAD. VERIFY THE PRESENCE OF ANY TOXIC MATERIALS PRIOR TO BIDDING THE WORK OR SUBMITTAL OF FINAL PRICE.

5

REINFORCED CONCRETE:

5.1

DESIGN CODE: BUILDING CODE REQUIREMENTS FOR STRUCTURAL CONCRETE (ACI 318), LATEST ADOPTION.

5.2

CONCRETE MIXES SHALL BE DESIGNED PER ACI 301 USING THE FOLLOWING:
PORTLAND CEMENT CONFORMING TO ASTM C150 OR C595
FLY ASH CONFORMING TO ASTM C618
SLAG CONFORMING TO ASTM C889
SILICA FUME CONFORMING TO ASTM C1240.
AGGREGATE CONFORMING TO ASTM C33
ADMIXTURES CONFORMING TO ASTM C494, C1017, AND C260. DO NOT USE CALCIUM CHLORIDE OR ADMIXTURES CONTAINING CALCIUM CHLORIDE.
CONCRETE SHALL BE READY-MIXED IN ACCORDANCE WITH ASTM C94.

5.3

MATERIAL STRENGTHS:

5.3.1

PROVIDE THE FOLLOWING CONCRETE PROPERTIES:

DESCRIPTION	COMPRESSIVE STRENGTH (FC) AT 28 DAYS	MAX AGGREGATE SIZE	SLUMP ²	MAX WATER TO CEMENT RATIOS (W/C) ³
INTERIOR SLABS ON GRADE	4000 PSI	¾"	3" ± 1"	0.43
ANY CONCRETE SUBJECT TO FREEZE-THAW CYCLES (5% ENTRAINED AIR) ¹	4500 PSI	¾"	4" ± 1"	0.45

¹ TOLERANCE ON AIR CONTENT AS DELIVERED SHALL BE ± 1.5%.

² PRIOR TO ADDITION OF PLASTICIZER OR HIGH-RANGE WATER-REDUCER

³ THESE W/C RATIOS MAY BE LOWER THAN NECESSARY TO PROVIDE THE SPECIFIED STRENGTHS.

5.3.2

REINFORCING STEEL:
ALL OTHER BARS, STIRRUPS AND TIES ASTM A615, GR. 60
WELDED WIRE FABRIC ASTM A1064

5.4

PLACEMENT OF CONCRETE AND REINFORCEMENT SHALL BE IN ACCORDANCE WITH ACI AND CRSI STANDARDS.

5.5

CLEAN REINFORCEMENT OF LOOSE RUST, MILL SCALE, EARTH, ICE, AND OTHER FOREIGN MATERIALS THAT REDUCE BOND TO CONCRETE.

5.6

FURNISH THE FOLLOWING CONCRETE COVER ON REINFORCING BARS UNLESS SHOWN OTHERWISE ON DRAWINGS:
SLABS ON GRADE.....CENTER MESH OR BARS IN SLAB

5.7

ALL WELDED WIRE FABRIC SHALL BE TRANSPORTED AND DELIVERED IN FLAT SHEETS.

5.8

MAINTAIN CONCRETE IN A CONTINUOUSLY DAMP AND WET CONDITION FOR NOT LESS THAN 7 DAYS AFTER PLACING. PROTECT FROM MOISTURE LOSS WITH SHEETING OR SPRAY-ON MEMBRANE MEETING ASTM C309 AND COMPATIBLE WITH FLOOR COVERINGS.

5.9

FINISHING REQUIREMENTS ARE AS FOLLOWS (REFER TO ACI 301):
SMOOTH RUBBED FINISH ON EXPOSED FORM SURFACES.
STEEL TROWEL FINISH ON INTERIOR SLABS AND SLABS TO RECEIVE FINISH FLOORING.

5.10

DO NOT FIELD BEND BARS PARTIALLY EMBEDDED IN HARDENED CONCRETE UNLESS SPECIFICALLY INDICATED OR ACCEPTED BY THE ENGINEER.

5.11

IN SLABS PROVIDE (2) #4x4'-0" DIAGONAL BARS AT 45 DEGREES AT ALL CORNERS OF OPENINGS AND RE-ENTRANT CORNERS.

5.12

COLD WEATHER CONCRETING SHALL FOLLOW PROCEDURES IN ACI 306.

5.13

HOT WEATHER CONCRETING SHALL FOLLOW PROCEDURES IN ACI 305.

5.14

FORMWORK SHALL REMAIN IN PLACE UNTIL CONCRETE HAS ATTAINED A MINIMUM COMPRESSIVE STRENGTH OF 3,000 PSI, UNLESS OTHERWISE DIRECTED BY THE ENGINEER. THE CONTRACTOR SHALL PROVIDE ALL SHORING.

5.15

SPECIAL ADDITIONAL REQUIREMENTS FOR SLABS ON GRADE:

5.15.1

DESIGN STANDARD: GUIDE FOR CONCRETE FLOOR AND SLAB CONSTRUCTION (ACI 302.1)

5.15.2

REFER TO GEOTECHNICAL REPORT FOR VAPOR BARRIER, ENGINEERED FILL AND SUBGRADE COMPACTION REQUIREMENTS.

5.15.3

LAP ADJOINING WELDED WIRE FABRIC AT LEAST TWO FULL MESHES.

5.15.4

SEE DRAWINGS FOR LOCATIONS OF SLAB CONTROL JOINTS.

5.15.5

SLAB JOINTS SHALL BE FILLED WITH AN ACCEPTED MATERIAL AS LATE AS POSSIBLE, PREFERABLY AT LEAST 4 TO 6 WEEKS AFTER THE SLAB HAS BEEN CAST. PRIOR TO FILLING, REMOVE ALL DEBRIS FROM THE SLAB JOINTS. FILL IN ACCORDANCE WITH THE MANUFACTURER'S RECOMMENDATIONS.

5.15.6

SEE THE ARCHITECTURAL DRAWINGS FOR EXACT LOCATIONS OF DEPRESSED SLAB AREAS AND DRAINS. SLOPE SLAB TO DRAINS WHERE SHOWN.

5.15.7

FINISH TOLERANCE OF ALL SLABS SHALL BE IN ACCORDANCE WITH ACI 302.1 R.

6

WOOD:

6.1

DESIGN CODE: NATIONAL DESIGN SPECIFICATION (NDS) FOR WOOD CONSTRUCTION (AF&PA), LATEST ADOPTION.

6.2

MATERIALS (FOLLOWING INDICATE MINIMUM GRADES UNO ON DRAWINGS):

DESCRIPTION	SPECIES & GRADE	DESIGN VALUES (PSI)				COMMENTS		
		Fb	FcL	FcL	E (x10 ⁶)			
FRAMING LUMBER	Dimensional Lumber (2"-4")	SPRUCE-PINE-FIR	NO. 2	875	425	1150	1.4	POSTS
	Timbers (5"x5" and larger)	SPRUCE-PINE-FIR	NO. 2	500	425	500	1.0	POSTS
	Dimensional Lumber (2"-4")	SPRUCE-PINE-FIR	NO. 2	875	425	1150	1.4	JOISTS, BEAMS AND LINTELS
	Timbers (5"x5" and larger)	SPRUCE-PINE-FIR	NO. 2	600	425	425	1.0	BEAMS

6.3

ALL LUMBER CONNECTORS TO BE SUPPLIED BY USP OR SIMPSON STRONG-TIE. WHERE LUMBER CONNECTORS ARE TO BE USED BUT ARE NOT CALLED OUT IN THESE DRAWINGS THEY ARE TO BE DESIGNED AND SUPPLIED BY USP OR SIMPSON STRONG-TIE FOR THE REACTION SHOWN ON THESE DRAWINGS. WHEN USING LUMBER CONNECTORS FILL ALL NAIL HOLES TO ACHIEVE PUBLISHED VALUE. WHERE MORE STRINGENT, THESE DRAWINGS SUPERSEDE DIRECTIONS IN PRODUCT CATALOG BUT REFER TO PRODUCT CATALOG FOR TYPICAL INSTALLATION INSTRUCTIONS.

6.4

TRUSS MEMBERS AND COMPONENTS SHALL NOT BE CUT, NOTCHED, DRILLED NOR OTHERWISE ALTERED IN ANY WAY WITHOUT THE WRITTEN APPROVAL OF THE TRUSS SUPPLIER'S STRUCTURAL ENGINEER.

6.5

COORDINATE MECHANICAL EQUIPMENT LOADS AND LOCATIONS WITH MECHANICAL/ARCHITECTURAL DRAWINGS AND MECHANICAL CONTRACTOR.

ABBREVIATIONS

ACI

AMERICAN CONCRETE INSTITUTE

CRSI

CONCRETE REINFORCING STEEL INSTITUTE

AF&PA

AMERICAN FOREST & PAPER ASSOCIATION

OSHA

OCCUPATIONAL SAFETY AND HEALTH ADMINISTRATION

APA

ENGINEERED WOOD ASSOCIATION

WTCA

WOOD TRUSS COUNCIL OF AMERICA

ASTM

AMERICAN SOCIETY FOR TESTING AND MATERIALS

CONSULTANT:

VAA

VAA ENG, LLC
2300 Berkshire Lane N, Suite 200
Plymouth, MN 55441
IL Firm Registration No. 184007783-0006

763.559.9100
www.vaaeng.com

CLIENT:

CHIPOTLE

MEXICAN GRILL

CHIPOTLE MEXICAN GRILL, INC.
PO BOX 182966
COLUMBUS, OH 43218-2966
TELEPHONE: (614) 318-2492
INTERNET: WWW.CHIPOTLE.COM

COPYRIGHT 2023
THIS DRAWING IS AN INSTRUMENT OF SERVICE AND AS SUCH REMAINS THE PROPERTY OF CHIPOTLE MEXICAN GRILL, INC. PERMISSION FOR USE OF THIS DOCUMENT IS LIMITED AND CAN BE EXTENDED ONLY BY WRITTEN AGREEMENT WITH CHIPOTLE MEXICAN GRILL, INC.

PROJECT INFORMATION:

STORE NO.: #5037

"HUNTLEY"

HUNTLEY CROSSINGS DR & IL STATE HWY 47 HUNTLEY, IL 60142

SEAL:

LICENSING BOARD
STATE OF ILLINOIS

HELLEY F. BERTON
081000877
HAWAIIAN ISLANDS
HAWAIIAN ISLANDS

11-02-24
5/6/24
Auto

PROJECT NO. 230353

DRAWN BY JWO

CHECKED BY TJM

ISSUE RECORD:

09.06.23 PERMIT SET

03.15.24 BID SET

05.03.24 CONSTRUCTION SET


REVISIONS:

TITLE:

GENERAL STRUCTURAL NOTES

SHEET NUMBER:


S000

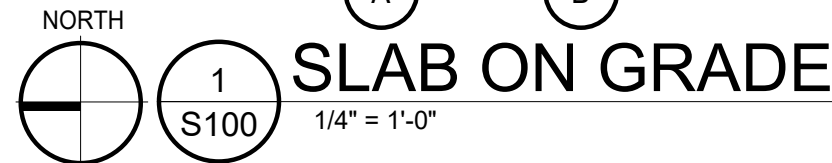

1. FOR GENERAL STRUCTURAL NOTES SEE SHEET S000.
2. CONTRACTOR TO FIELD VERIFY ALL EXISTING DIMENSIONS, ELEVATIONS, CONDITIONS, ETC PRIOR TO DEMOLITION, FABRICATION AND CONSTRUCTION.
3. EXISTING STRUCTURAL INFORMATION IS BASED ON THE STRUCTURAL DRAWINGS PREPARED BY VAA ENG. LLC DATED 08.14.2023.




S100

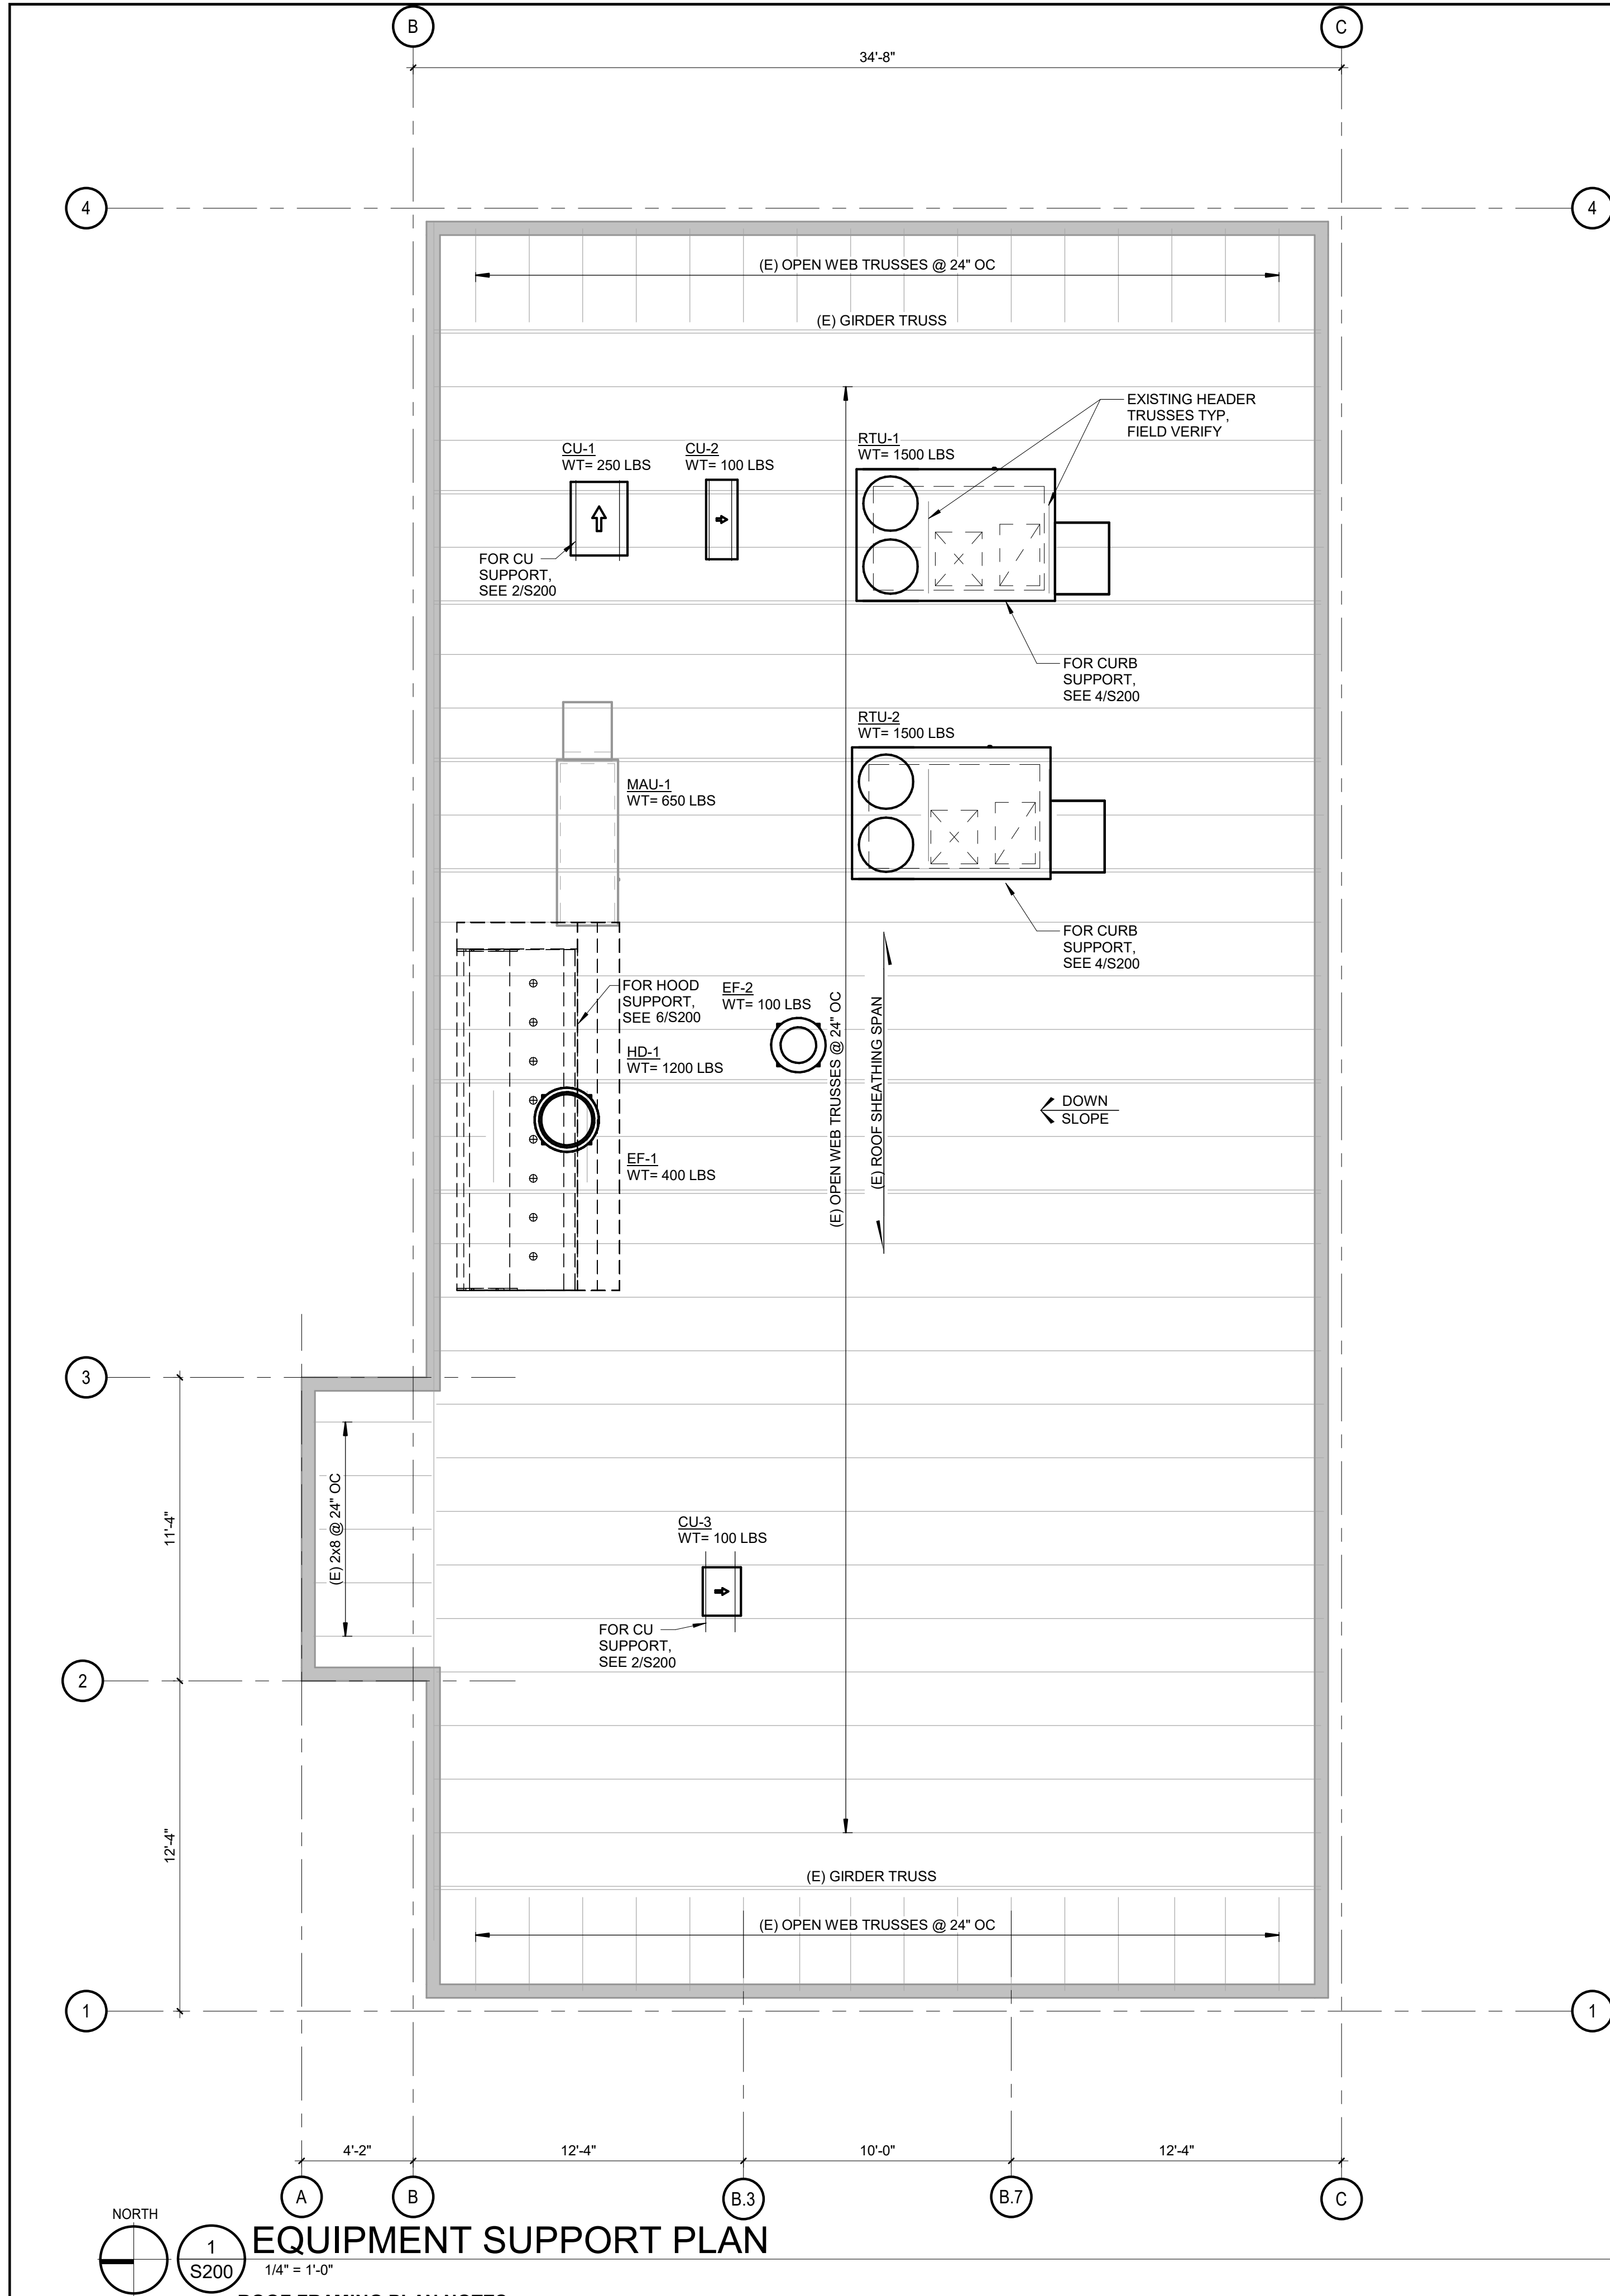


ROOF FRAMING PLAN NOTES:


- FOR GENERAL STRUCTURAL NOTES SEE SHEET S000.
- CONTRACTOR TO FIELD VERIFY ALL EXISTING DIMENSIONS, ELEVATIONS, CONDITIONS, ETC PRIOR TO DEMOLITION, FABRICATION AND CONSTRUCTION
- FOR CONCENTRATED LOADS SUSPENDED FROM EXISTING ROOF TRUSSES SEE 3/S200.
- FOR ROOF DECK OPENINGS LARGER THAN 8\"
- THE LANDLORD SHELL ENGINEER AND TRUSS SUPPLIER TO DESIGN THE ROOF STRUCTURE TO ACCOMMODATE LOADS SHOWN.
- EXISTING STRUCTURAL INFORMATION IS BASED ON THE STRUCTURAL DRAWINGS PREPARED BY VAA ENG, LLC DATED 08.14.2023.

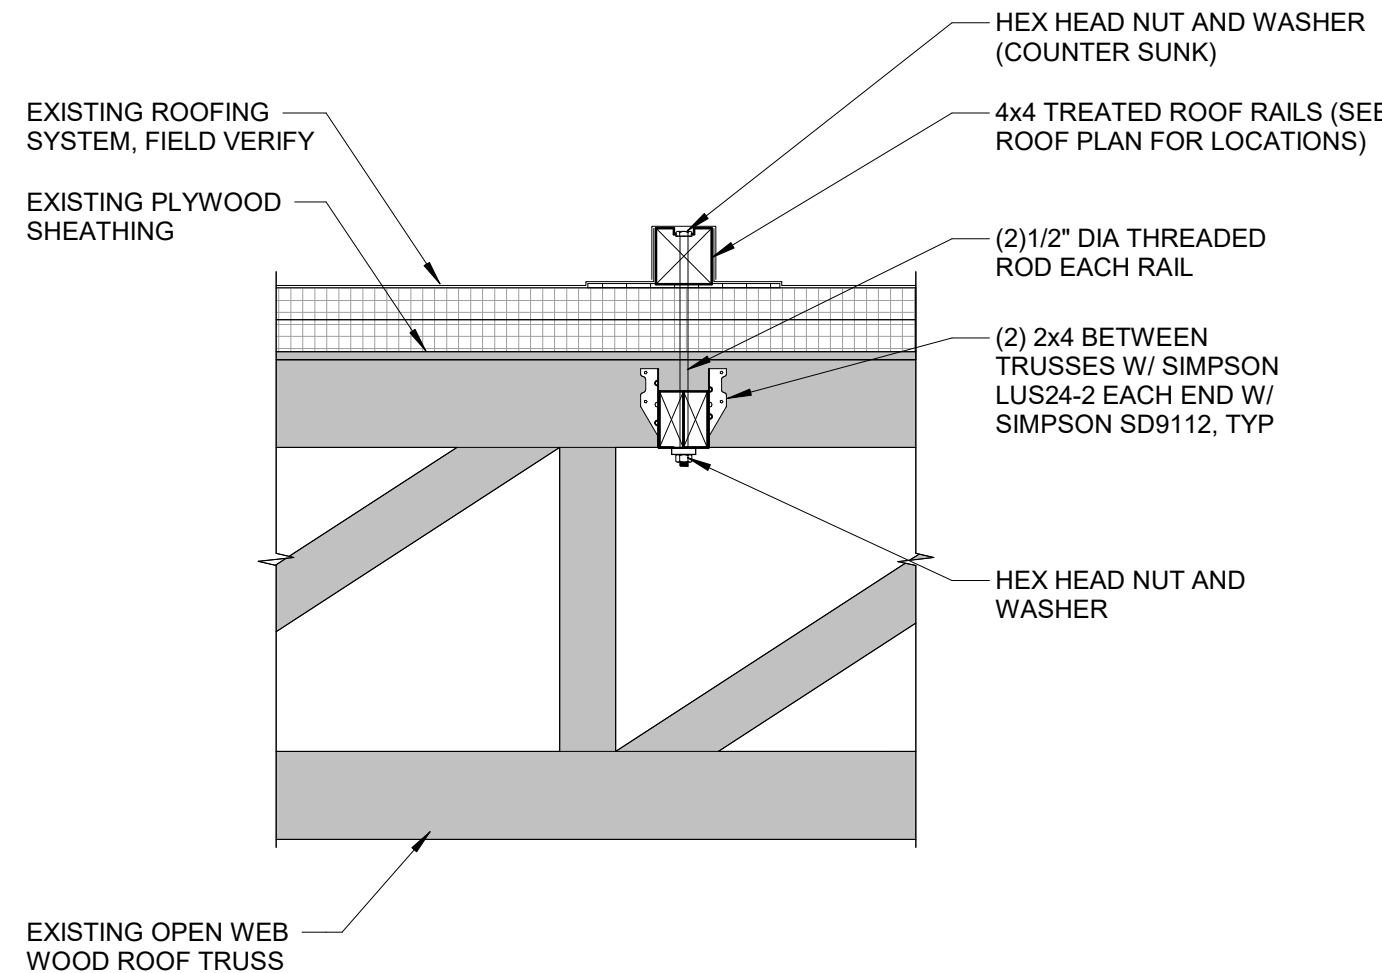


2 CU SUPPORT DETAIL
1\"

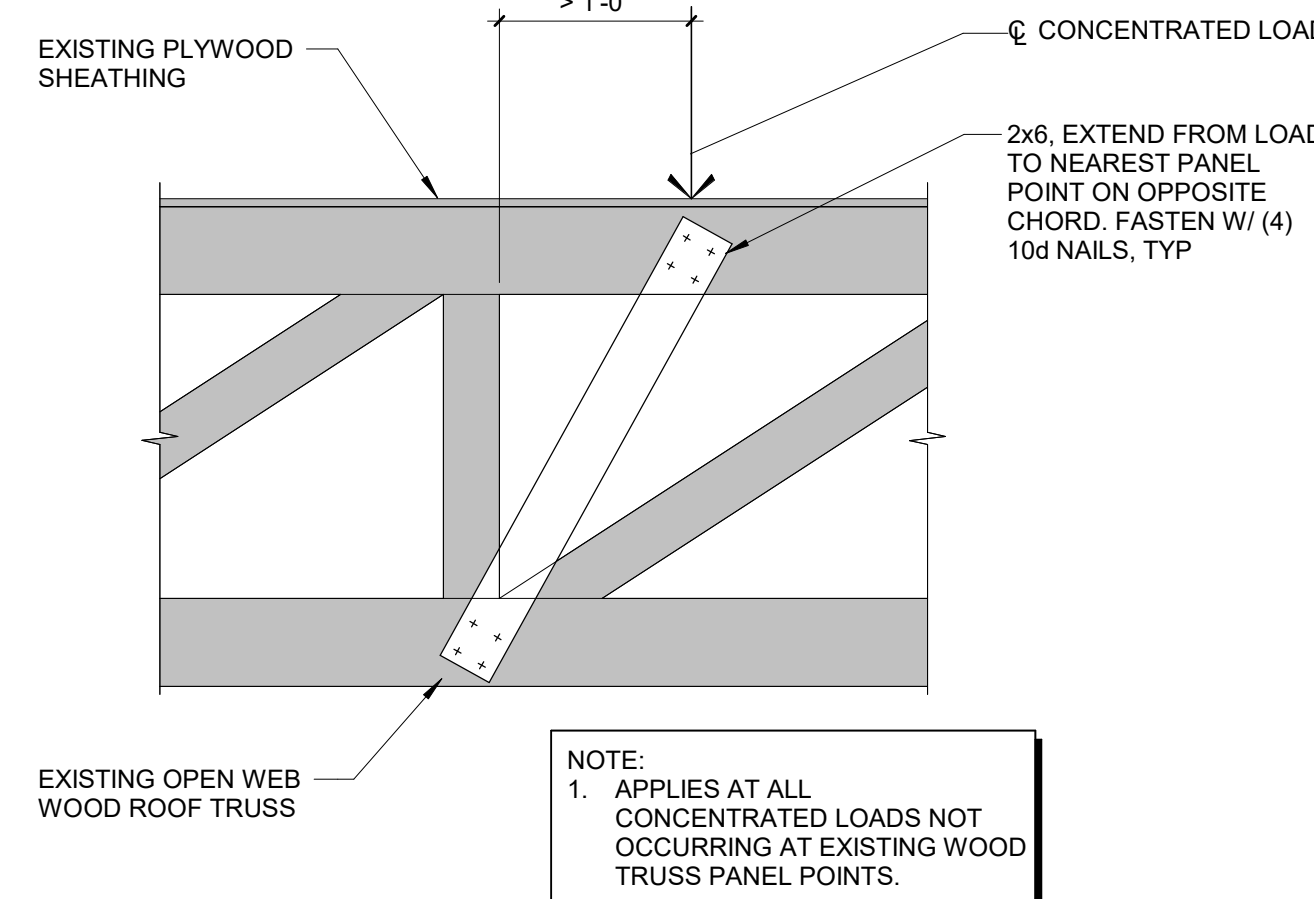


3 TRUSS CHORD REINFORCING DETAIL
1\"

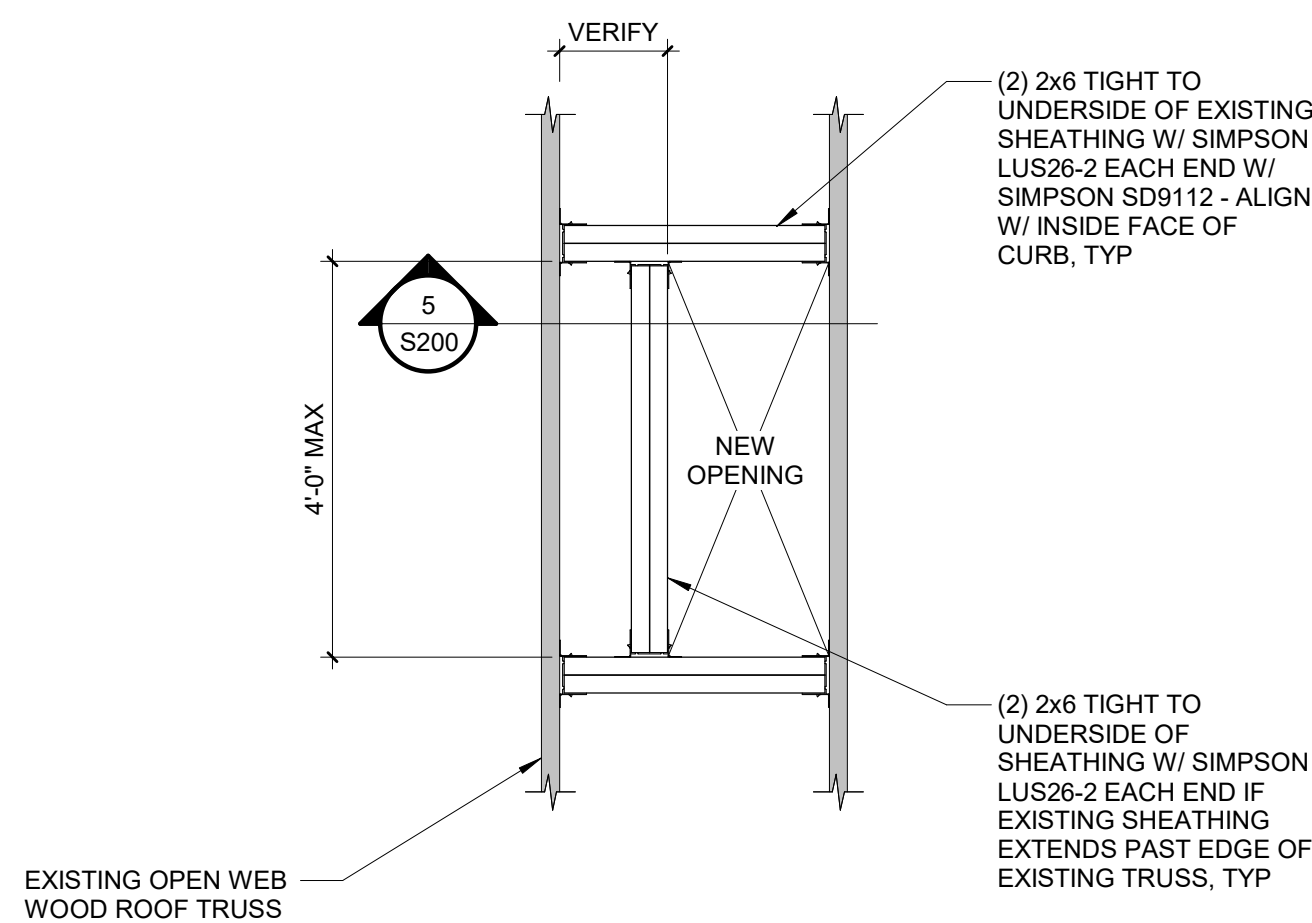

4 ROOF FRAME DETAIL
3/4\"

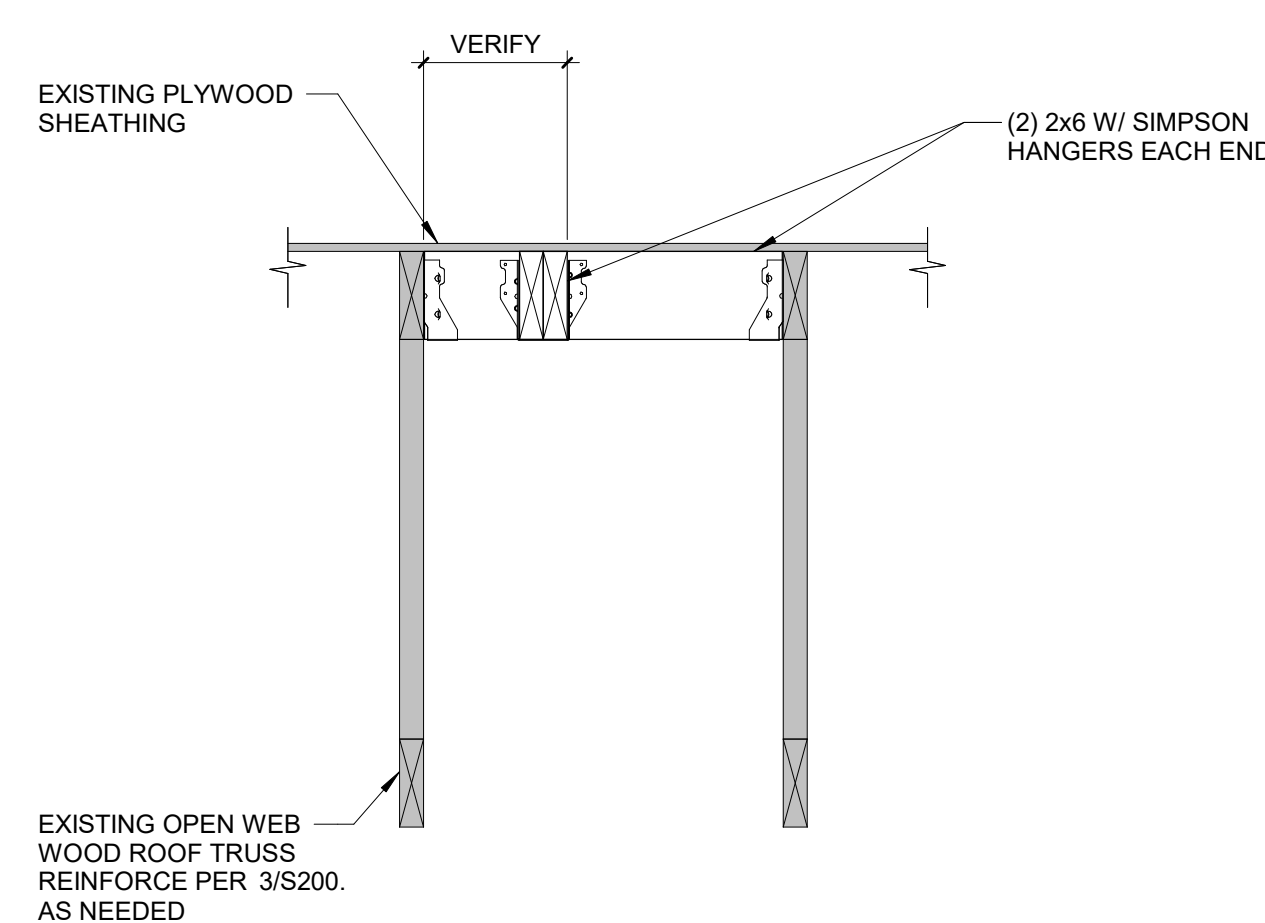

5 ROOF FRAME DETAIL
1\"

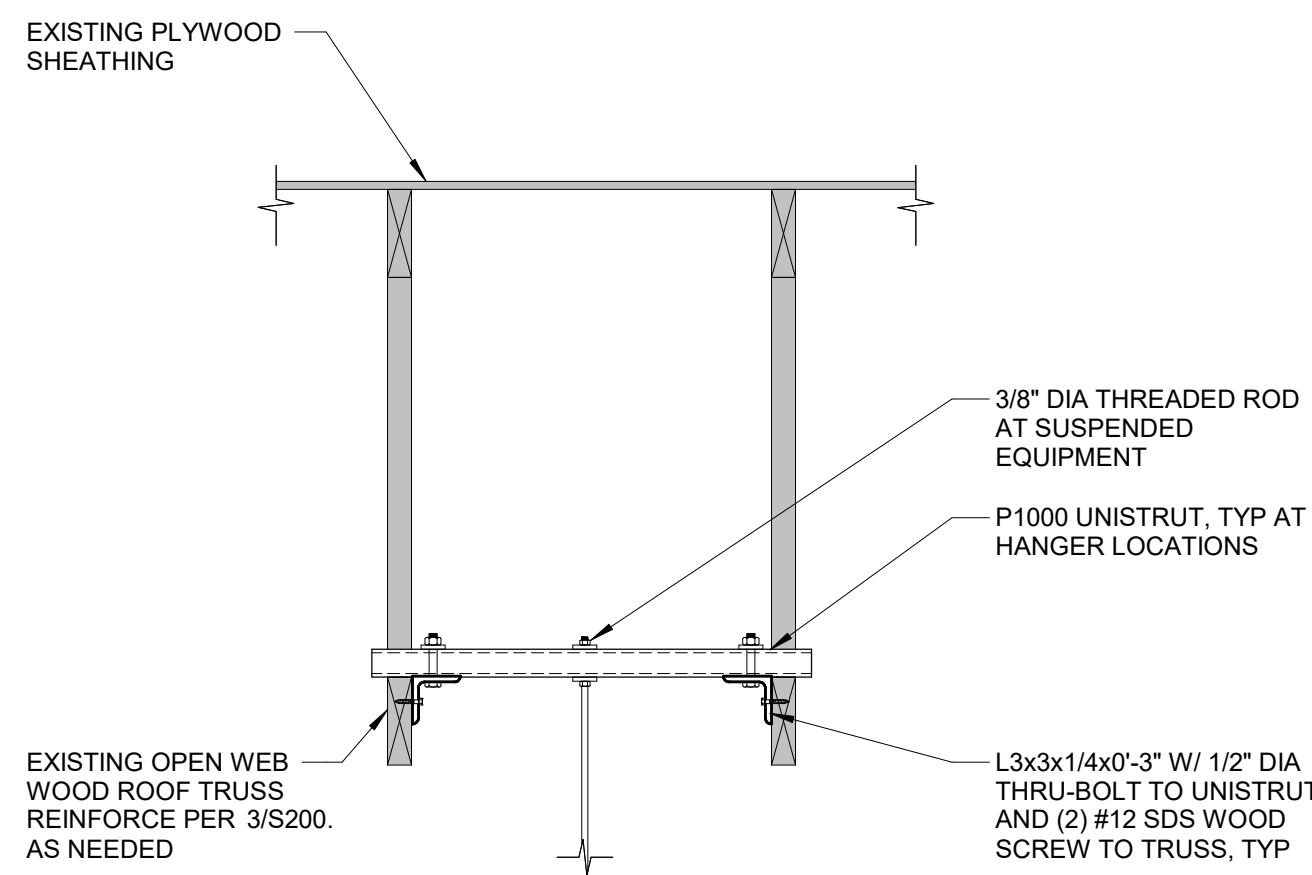

6 SUSPENDED EQUIPMENT DETAIL
1\"

CONSULTANT:



VAA ENG, LLC
2300 Berkshire Lane N, Suite 200
Plymouth, MN 55441
IL Firm Registration No. 184007783-0006

CLIENT:



CHIPOTLE MEXICAN GRILL, INC.
PO BOX 182966
COLUMBUS, OH 43218-2966
TELEPHONE: (614) 315-2652
INTERNET: WWW.CHIPOTLE.COM

COPYRIGHT 2023
THIS DRAWING IS AN INSTRUMENT OF SERVICE AND AS SUCH REMAINS THE PROPERTY OF CHIPOTLE MEXICAN GRILL, INC. PERMISSION FOR USE OF THIS DOCUMENT IS LIMITED AND CAN BE EXTENDED ONLY BY WRITTEN AGREEMENT WITH CHIPOTLE MEXICAN GRILL, INC.

PROJECT INFORMATION:

STORE NO.: #5037

"HUNTLEY"
HUNTLEY CROSSINGS DR & IL STATE
HWY 47 HUNTLEY, IL 60142

SEAL:



11-30-24
5/6/24
Auto

PROJECT NO. 230353
DRAWN BY JWO
CHECKED BY TJM

ISSUE RECORD:
01.30.2024 PERMIT SET
03.15.2024 BID SET
05.03.2024 CONSTRUCTION SET

REVISIONS:

TITLE:

EQUIPMENT
SUPPORT PLAN
AND DETAILS

SHEET NUMBER:

S200

FOR REFERENCE ONLY:
FIRE PROTECTION AND ALARM
SYSTEMS ARE TO BE DESIGNED BY
THE GENERAL CONTRACTOR

FIRE PROTECTION GENERAL NOTES


- A FIRE PROTECTION WORK SHALL BE DONE IN ACCORDANCE WITH THE BUILDING CODE, NFPA, LOCAL FIRE DEPARTMENT STANDARDS, AND THE AUTHORITY HAVING JURISDICTION. SEE ARCHITECTURAL SHEETS FOR THE PREVAILING CODES.
- B CEILING HEIGHTS SHOWN IN THE FIRE PROTECTION SCHEDULE ARE APPROXIMATE. SEE ARCHITECTURAL REFLECTED CEILING PLAN FOR EXACT CEILING HEIGHTS.
- C EXISTING FIRE PROTECTION SYSTEM: EXISTING WET PIPE SPRINKLER SYSTEM WITH DISTRIBUTION THROUGHOUT SPACE AND HEADS TURNED UP TO DECK.
- D EXISTING FIRE ALARM SYSTEM: EXISTING ADDRESSABLE FIRE ALARM SYSTEM WITH FACP IN BASE BUILDING RISER ROOM, NOTIFICATION APPLIANCE IN SPACE, AND PULL STATIONS AT EXITS.
- E FIRE ALARM SCOPE OF WORK: MODIFY THE EXISTING FIRE ALARM SYSTEM IN THE SPACES SHOWN TO SUIT THE NEW FLOOR PLAN. PROVIDE NEW DEVICES AS NECESSARY FOR A COMPLETE SYSTEM.
- F COORDINATE HEAD AND DEVICE LAYOUT WITH EXPOSED DUCTWORK, LIGHT FIXTURES, HVAC EQUIPMENT, ARCHITECTURAL CEILING ELEMENTS, AND WALL-MOUNTED EQUIPMENT. SEE ARCHITECTURAL, HVAC, PLUMBING, AND ELECTRICAL PLANS FOR LOCATIONS. PROVIDE HEADS AND DEVICES IN LAY-IN CEILINGS AT QUARTER POINTS ALONG LONG AXIS OF CEILING TILES.
- G FIRE PROTECTION SCOPE OF WORK: MODIFY THE EXISTING HEAD LAYOUT IN THE SPACES SHOWN TO SUIT THE NEW FLOOR PLAN. PROVIDE NEW HEADS AND PIPING AS NECESSARY FOR A COMPLETE SYSTEM. PROVIDE HYDRAULIC CALCULATIONS FOR REVISED FIRE PROTECTION SYSTEM.
- H OBTAIN PERMITS, APPROVALS, AND INSPECTIONS FOR REVISED FIRE PROTECTION AND ALARM SYSTEMS.
- I CEILING HEIGHTS AND CEILING FIXTURE PLACEMENTS SHOWN ARE APPROXIMATE. SEE ARCHITECTURAL RCP FOR EXACT CEILING HEIGHTS AND CEILING FIXTURE DIMENSIONS.
- J SUBMIT FIRE PROTECTION AND FIRE ALARM SHOP DRAWINGS SHOWING HEAD AND DEVICE LAYOUTS TO ARCHITECT PRIOR TO SUBMITTING FOR PERMIT APPROVAL.
- K THE TERM "FURNISH" MEANS SUPPLY AND DELIVER TO THE PROJECT SITE, READY FOR UNLOADING, UNPACKING, ASSEMBLY, INSTALLATION, AND SIMILAR OPERATIONS. THE TERM "INSTALL" DESCRIBES THE OPERATIONS AT THE PROJECT SITE INCLUDING THE ACTUAL UNLOADING, UNPACKING, ASSEMBLY, ERECTING, PLACING, ANCHORING, APPLYING, WORKING TO DIMENSION, FINISHING, CURING, PROTECTING, CLEANING, AND SIMILAR OPERATIONS. THE TERM "PROVIDE" MEANS TO FURNISH AND INSTALL, COMPLETE AND READY FOR THE INTENDED USE.
- L IF A SLAT CEILING SYSTEM IS INSTALLED IN THE DINING ROOM WHERE IT WILL INTERFERE WITH THE PATTERN DEVELOPMENT OF SPRINKLER HEADS ABOVE THE SLAT CEILING (WITHIN 18" BELOW SPRINKLER HEADS) THEN PROVIDE INTERMEDIATE LEVEL IN-RACK PENDANT SPRINKLER HEADS IN SLAT CEILING SYSTEM PER THE ARCHITECTURAL DETAILS.

F.P. ABBREVIATIONS

- | | |
|-------|---------------------------------|
| (E) | EXISTING |
| ABV | ABOVE |
| ADA | AMERICANS WITH DISABILITIES ACT |
| AFF | ABOVE FINISHED FLOOR |
| AFG | ABOVE FINISHED GRADE |
| AHJ | AUTHORITY HAVING JURISDICTION |
| BFF | BELOW FINISHED FLOOR |
| BFG | BELOW FINISHED GRADE |
| BOH | BACK OF HOUSE |
| CLG | CEILING |
| CTE | CONNECT TO EXISTING |
| DN | DOWN |
| EXT'G | EXISTING |
| FAAP | FIRE ALARM ANNUNCIATOR PANEL |
| FACP | FIRE ALARM CONTROL PANEL |
| FLR | FLOOR |
| FOH | FRONT OF HOUSE |
| GYP | GYPSUM BOARD |
| NTS | NOT TO SCALE |
| O/H | OVERHEAD |
| TYP | TYPICAL |
| UG | UNDERGROUND |
| UNO | UNLESS NOTED OTHERWISE |
| W/ | WITH |
| WIC | WALK-IN COOLER |
-
- | | |
|-------|--|
| C02AS | TENANT'S C02 ALARM SUPPLIER |
| GC | GENERAL CONTRACTOR |
| HES | TENANT'S HVAC EQUIPMENT SUPPLIER |
| HS | TENANT'S HOOD SUPPLIER |
| KES | TENANT'S KITCHEN EQUIPMENT SUPPLIER |
| LL | LANDLORD |
| TAB | TENANT'S TEST AND BALANCE VENDOR |
| TCC | TENANT'S CABLING CONTRACTOR |
| TDC | TENANT'S DUCT CLEANER |
| TEMS | TENANT'S ENERGY MANAGEMENT SYSTEM SUPPLIER |
| TLS | TENANT'S LIGHT/LAMP SUPPLIER |
| TMB | TENANT'S MENU BOARD SUPPLIER |
| TMS | TENANT'S MILLWORK SUPPLIER |
| TP | TENANT'S PHONE SUPPLIER |
| TRS | TENANT'S RAILING SUPPLIER |
| TSV | TENANT'S SIGN VENDOR |
| TUV | TENANT'S UV SANITIZER SUPPLIER |
| WCS | TENANT'S WALK-IN COOLER SUPPLIER |
| WHS | TENANT'S WATER HEATER SUPPLIER |

FIRE PROTECTION SCHEDULE				
ROOM #	DESCRIPTION	CEILING	HEIGHT	HAZARD
100	MAIN ENTRY			
101	DINING			
102	UTENSIL			
103	PASSAGE			
104	POS			
105	ORDERING			
106	SERVING			
107	COOKING			
108	KITCHEN			
109	OFFICE			

F.P. MATERIAL SCHEDULE	
APPLICATION	ALLOWABLE MATERIAL (SPRINKLER HEAD)
EXPOSED STRUCTURE CEILING	CHROME OR BRASS UPRIGHT
GYPSUM BOARD CEILING	CHROME RECESSED PENDANT W/ CHROME ESCUTCHEON
LAY-IN CEILING	CHROME RECESSED PENDANT W/ CHROME ESCUTCHEON
STONEWOOD	CONCEALED PENDANT WITH BLACK COVER PLATE
WALK-IN COOLER	FREEZE-PROOF PENDANT

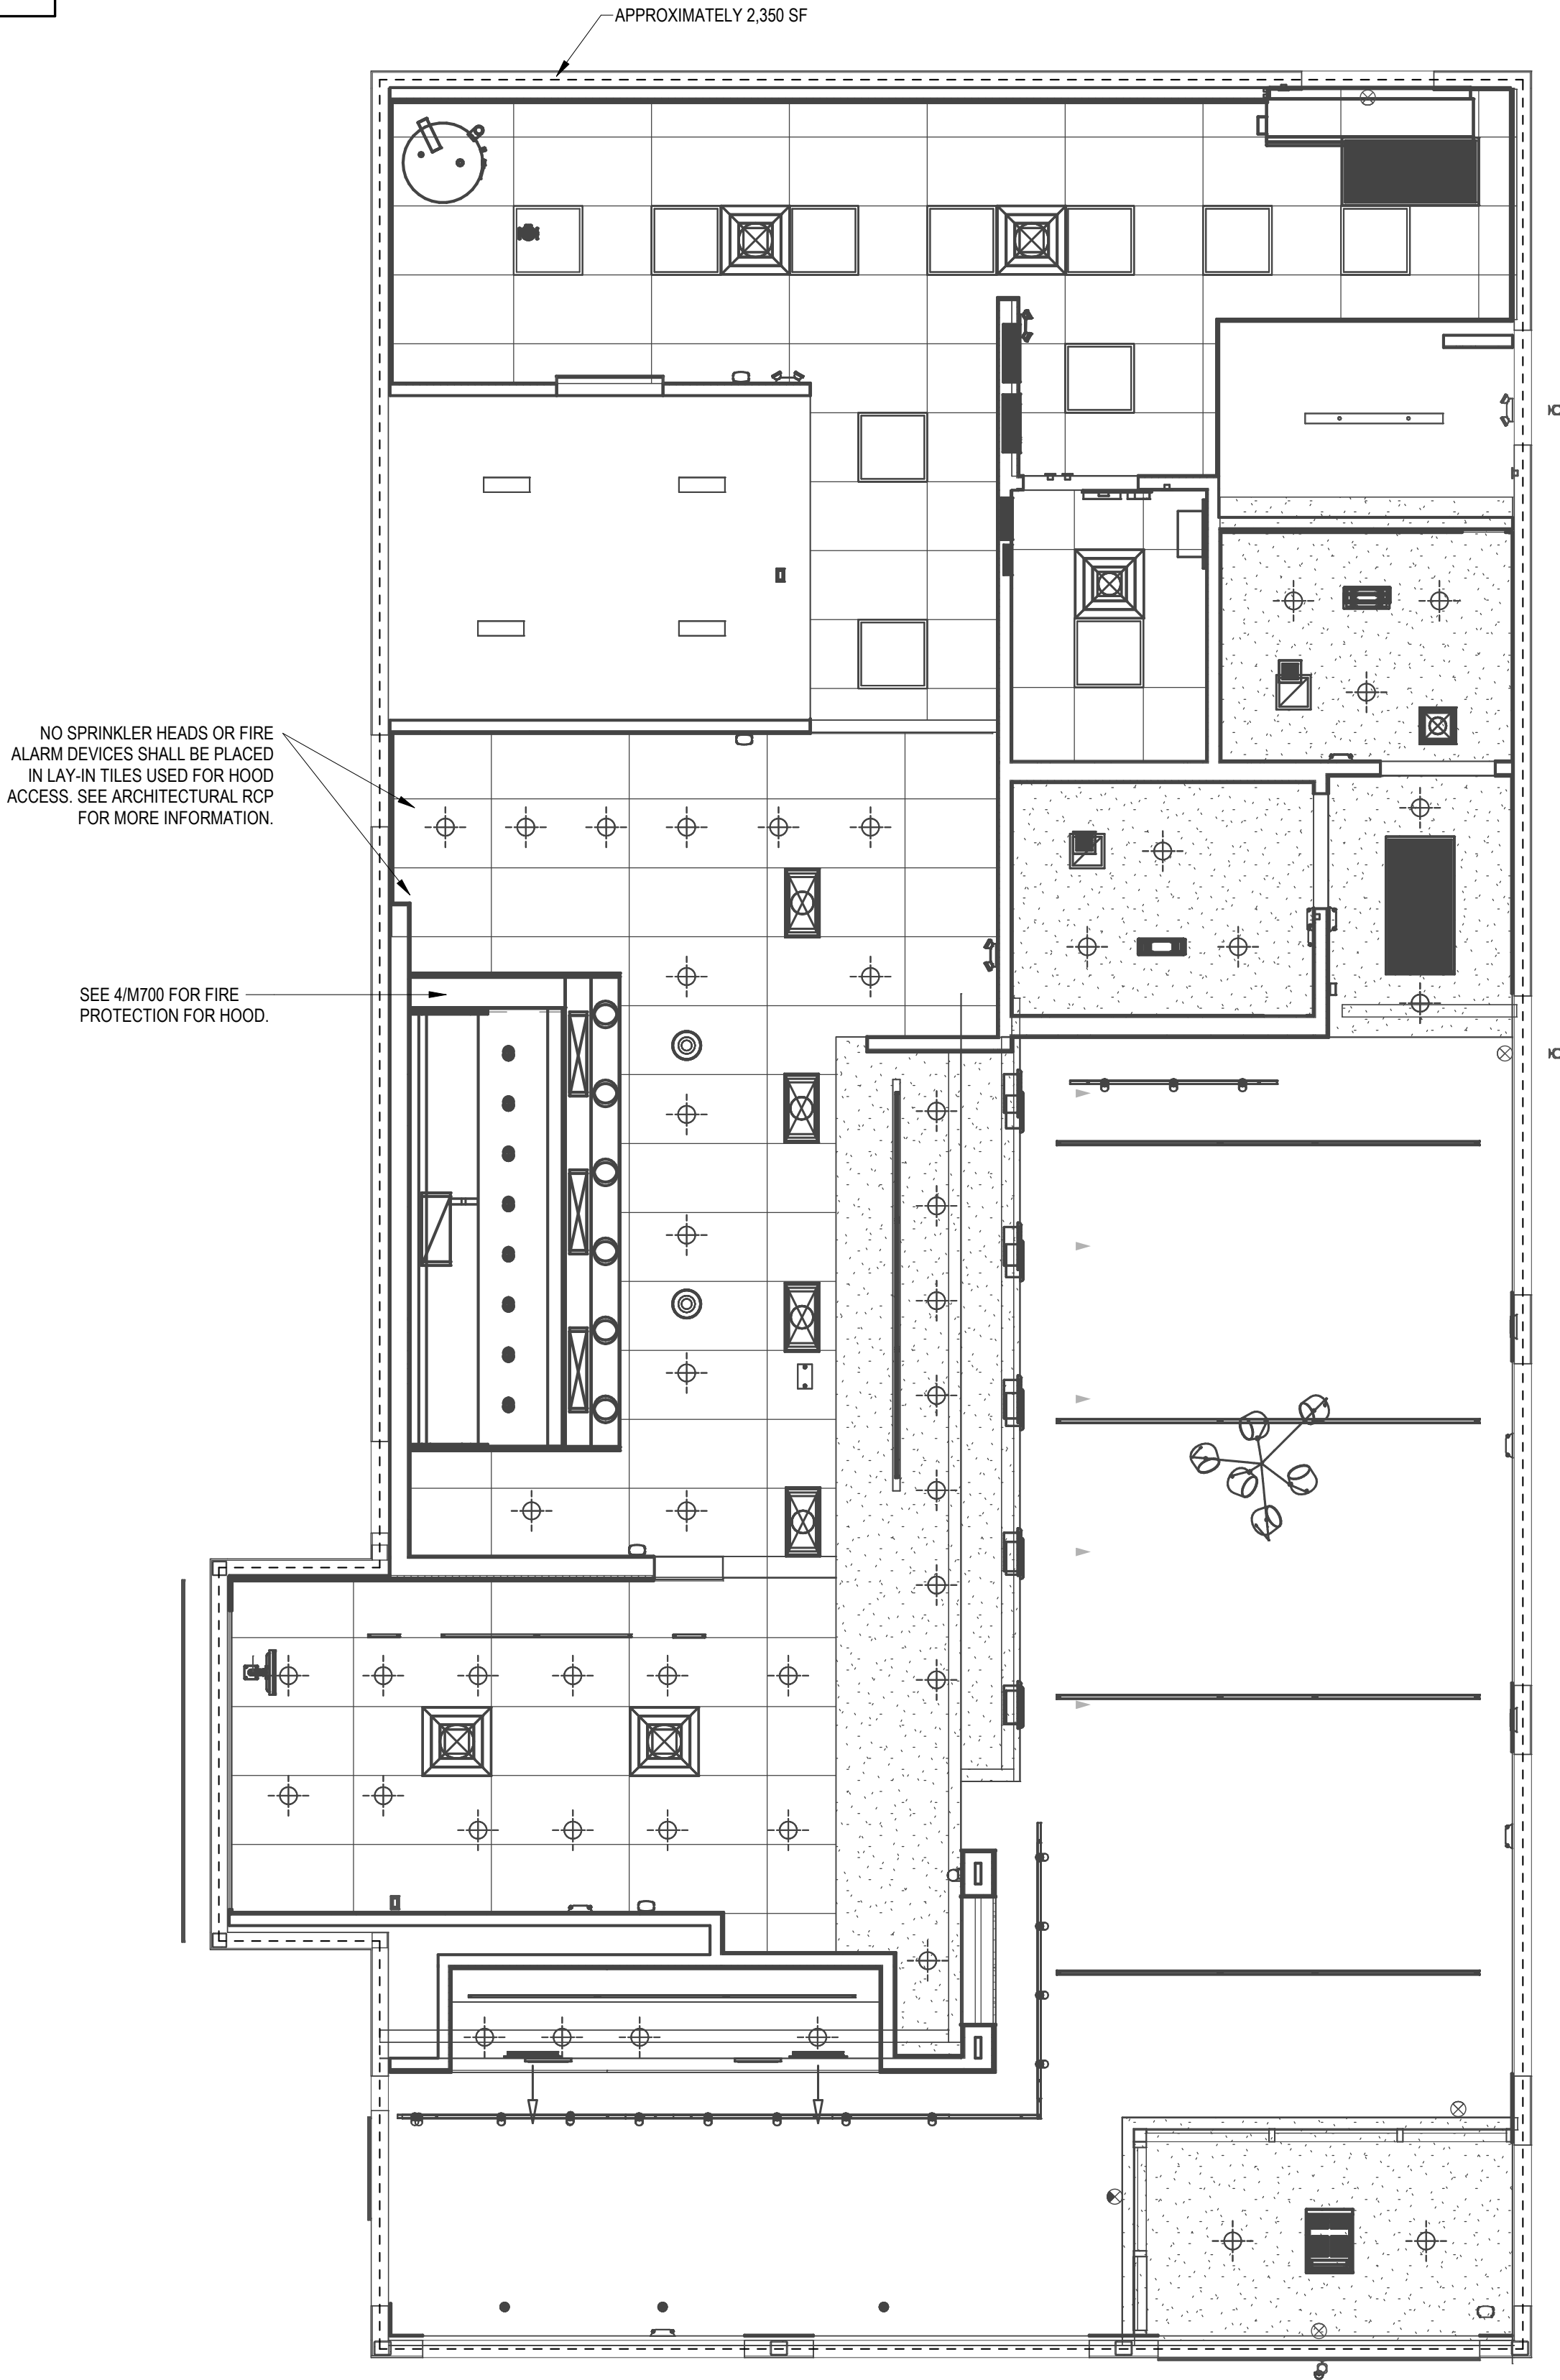

Consultant:

AYRES
MECHANICAL, ELECTRICAL,
PLUMBING (MEP)
1700 West Highway 36 - Suite 700
Roseville, Minnesota 55113
(651) 639-9606 Fax (651) 639-9618
Project No. 81-0606



COPYRIGHT 2024
THIS DRAWING IS AN INSTRUMENT OF SERVICE AND AS SUCH REMAINS THE PROPERTY OF CHIPOTLE MEXICAN GRILL, INC. PERMISSION FOR USE OF THIS DOCUMENT IS LIMITED AND CAN BE EXTENDED ONLY BY WRITTEN AGREEMENT WITH CHIPOTLE MEXICAN GRILL, INC.



STORE NO.: 5037
"HUNTLEY"
12990 ROUTE 47, LOT 4B
HUNTLEY, IL 60142

Issue Record:	
01/30/2024	PERMIT SUBMITTAL
03/15/2024	BID SET
05/03/2024	CONSTRUCTION SET

Revisions:

Drawn:	Checked:
RLD	LAO

Project No.

2023-0175


Contents:

FIRE PROTECTION
PLAN


F100

HVAC PLAN NOTES


- SEE ARCHITECTURAL REFLECTED CEILING PLAN FOR CEILING MOUNTED EQUIPMENT LOCATION. TYPICAL.
- PAINT DUCTWORK VISIBLE THROUGH DINING ROOM SUPPLY REGISTERS BLACK. TYPICAL.
- NOT USED.
- DUCT UP FOR TRANSITION TO RTU-1 RETURN CONNECTION IN ROOF CURB. RTU-1 SHALL HAVE AN INTEGRAL SMOKE DETECTOR MOUNTED IN THE RETURN AIR STREAM. INTERLOCK SMOKE DETECTOR TO RTU-1 OPERATION.
- RETURN DUCT UP THROUGH ROOF TO TRANSITION TO RTU-2 IN ROOF CURB. RETURN DUCT SHALL HAVE AN INTEGRAL SMOKE DETECTOR MOUNTED IN THE RETURN AIR STREAM. INTERLOCK SMOKE DETECTOR TO RTU-2 OPERATION.
- SUPPLY DUCT UP THROUGH ROOF TO TRANSITION TO RTU-1 IN ROOF CURB.
- SUPPLY DUCT UP THROUGH ROOF TO TRANSITION TO RTU-2 IN ROOF CURB.
- DUCT UP THROUGH ROOF. TRANSITION TO MAU-1 SUPPLY CONNECTION IN ROOF CURB.
- 10/17 DUCT UP FROM HOOD TO DUCT THROUGH ROOF TO EF-1 COMPLIANT WITH NFPA 96. PROVIDE RADIUS ELBOWS WITH AN INSIDE RADIUS OF 0.5W AT ELBOWS IN GREASE DUCT.
- DUCT UP THROUGH ROOF TO EF-2.
- 28/6 DUCT DOWN TO MAKEUP AIR PSP DUCT CONNECTION. TRANSITION TO SUPPLY PLENUM OPENING SIZE. TYPICAL FOR 3.
- 8" DIA. DUCT DOWN TO AC PSP DUCT CONNECTION. TRANSITION TO SUPPLY PLENUM OPENING SIZE. TYPICAL. CAP UNUSED DUCT CONNECTIONS.
- INSTALL GRIDPOINT THERMOSTATS FURNISHED BY TEMS FOR RTU-1 AND RTU-2 AT THIS LOCATION AT 48" AFF. COORDINATE WITH ELECTRICAL SWITCHING IN THIS AREA. PROVIDE WIRING AS SHOWN IN DETAIL 8/E710.
- INSTALL GRIDPOINT ZONE SENSOR MODULE FURNISHED BY TEMS FOR RTU-1 AT THIS LOCATION 60" AFF DIRECTLY TO WALL (NO JUNCTION BOX). COORDINATE LOCATION WITH EQUIPMENT. PROVIDE WIRING AS SHOWN IN DETAIL 8/E710.
- INSTALL GRIDPOINT ZONE SENSOR MODULE FURNISHED BY TEMS FOR RTU-2 AT THIS LOCATION 66" AFF DIRECTLY TO WALL (NO JUNCTION BOX). COORDINATE LOCATION WITH EQUIPMENT. PROVIDE WIRING AS SHOWN IN DETAIL 8/E710.
- INSTALL GRIDPOINT SUPPLY PROBE FURNISHED BY TEMS FOR RTU-1 IN THE SUPPLY DUCTWORK UPSTREAM FROM THE FIRST BRANCH CONNECTION. PROVIDE WIRING AS SHOWN IN DETAIL 8/E710.
- INSTALL GRIDPOINT SUPPLY PROBE FURNISHED BY TEMS FOR RTU-2 IN THE SUPPLY DUCTWORK UPSTREAM FROM THE FIRST BRANCH CONNECTION. PROVIDE WIRING AS SHOWN IN DETAIL 8/E710.
- INSTALL REMOTE TEMPERATURE SENSOR FOR HOOD HD-1 AT THIS LOCATION 66" AFF. COORDINATE LOCATION WITH EQUIPMENT. PROVIDE (2) #18 G. THERMISTOR CABLE FROM TEMPERATURE SENSOR TO HOOD CONTROL PANEL.
- INSTALL KITCHEN HOOD. HD-1. SUPPORT HOOD PER MANUFACTURER'S INSTALLATION INSTRUCTIONS AND AS DETAILED IN THE ARCHITECTURAL AND STRUCTURAL DRAWINGS. INSTALL HOOD ACCORDING TO THE REQUIREMENTS OF ITS LISTING. IN COMPLIANCE WITH NFPA 96, THE BUILDING CODE, AND AUTHORITIES HAVING JURISDICTION. HOOD SHALL HAVE AN INTEGRAL DUCT COLLAR TEMPERATURE SENSOR TO AUTOMATICALLY ENERGIZE THE EXHAUST AND MAKEUP AIR FANS IF COOKING TEMPERATURES ARE DETECTED. EXHAUST DUCT SYSTEM TO BE WELDED OR FACTORY-MANUFACTURED WATER AND AIR TIGHT. INSTALL CLEANOUTS PER CODE AND AS SHOWN. INSTALL HOOD PER DETAILS 2, 4, AND 9/M700. CHIPOTLE WILL PROVIDE AN INDEPENDENT TESTING AGENCY FOR TESTING THE INTEGRITY OF THE GREASE DUCT SYSTEM.

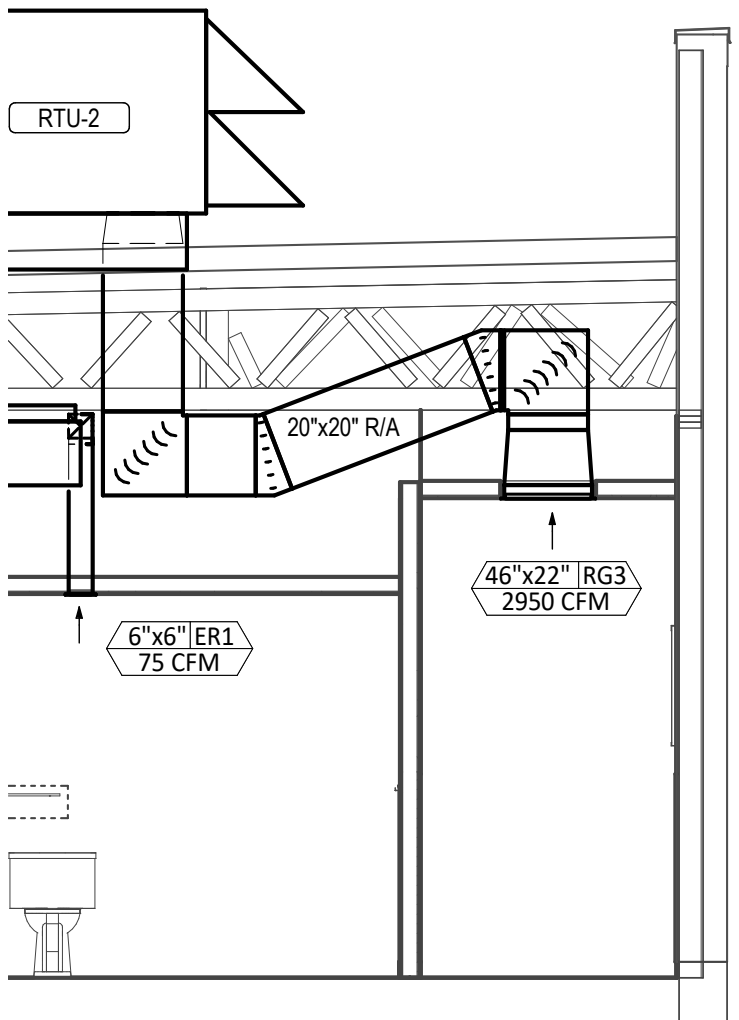


6 HVAC DINING ROOM RETURN SECTION
1/4" = 1'-0"

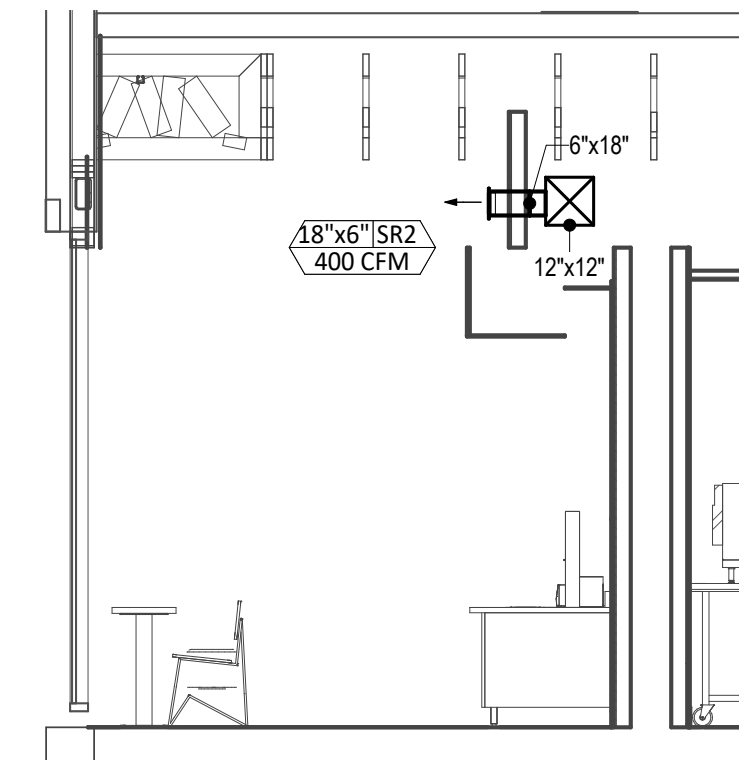

5 HVAC DINING ROOM SECTION
1/4" = 1'-0"

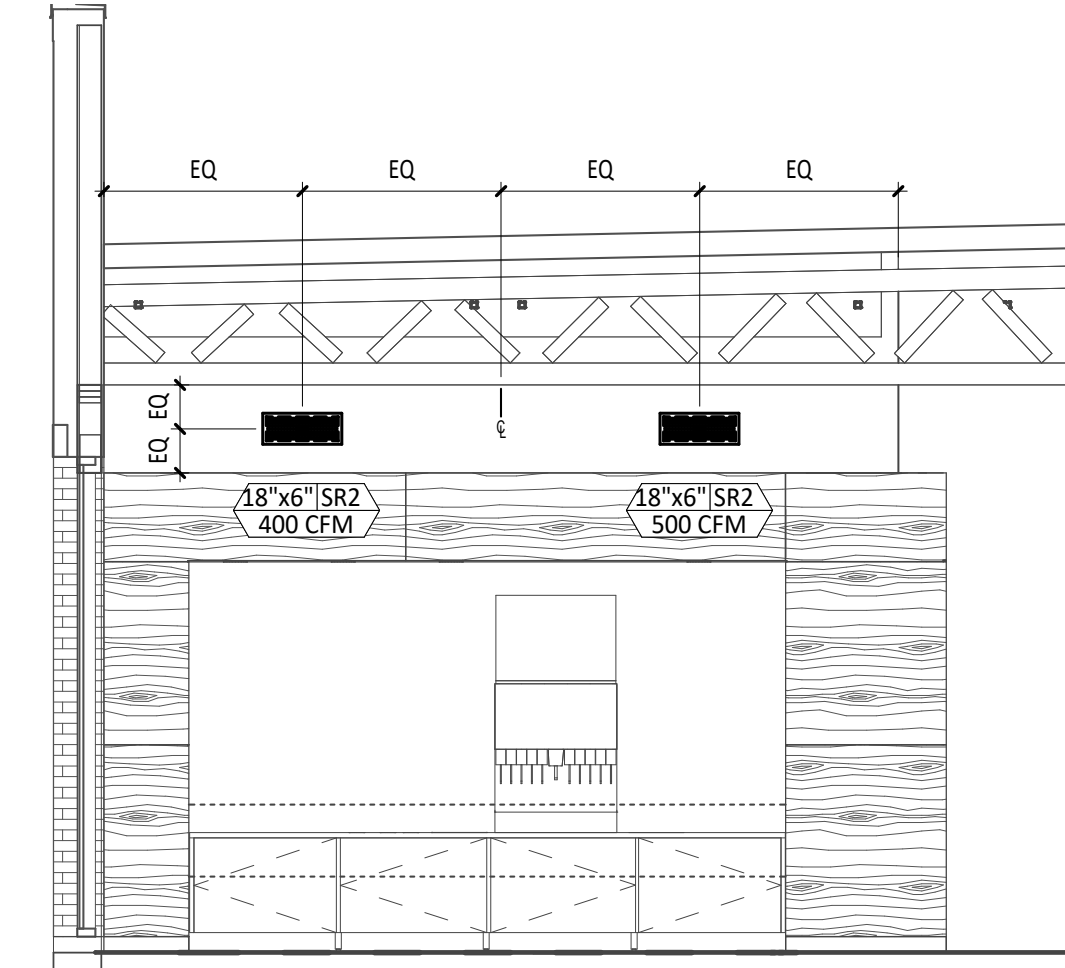


4 HVAC DINING ROOM SECTION
1/4" = 1'-0"

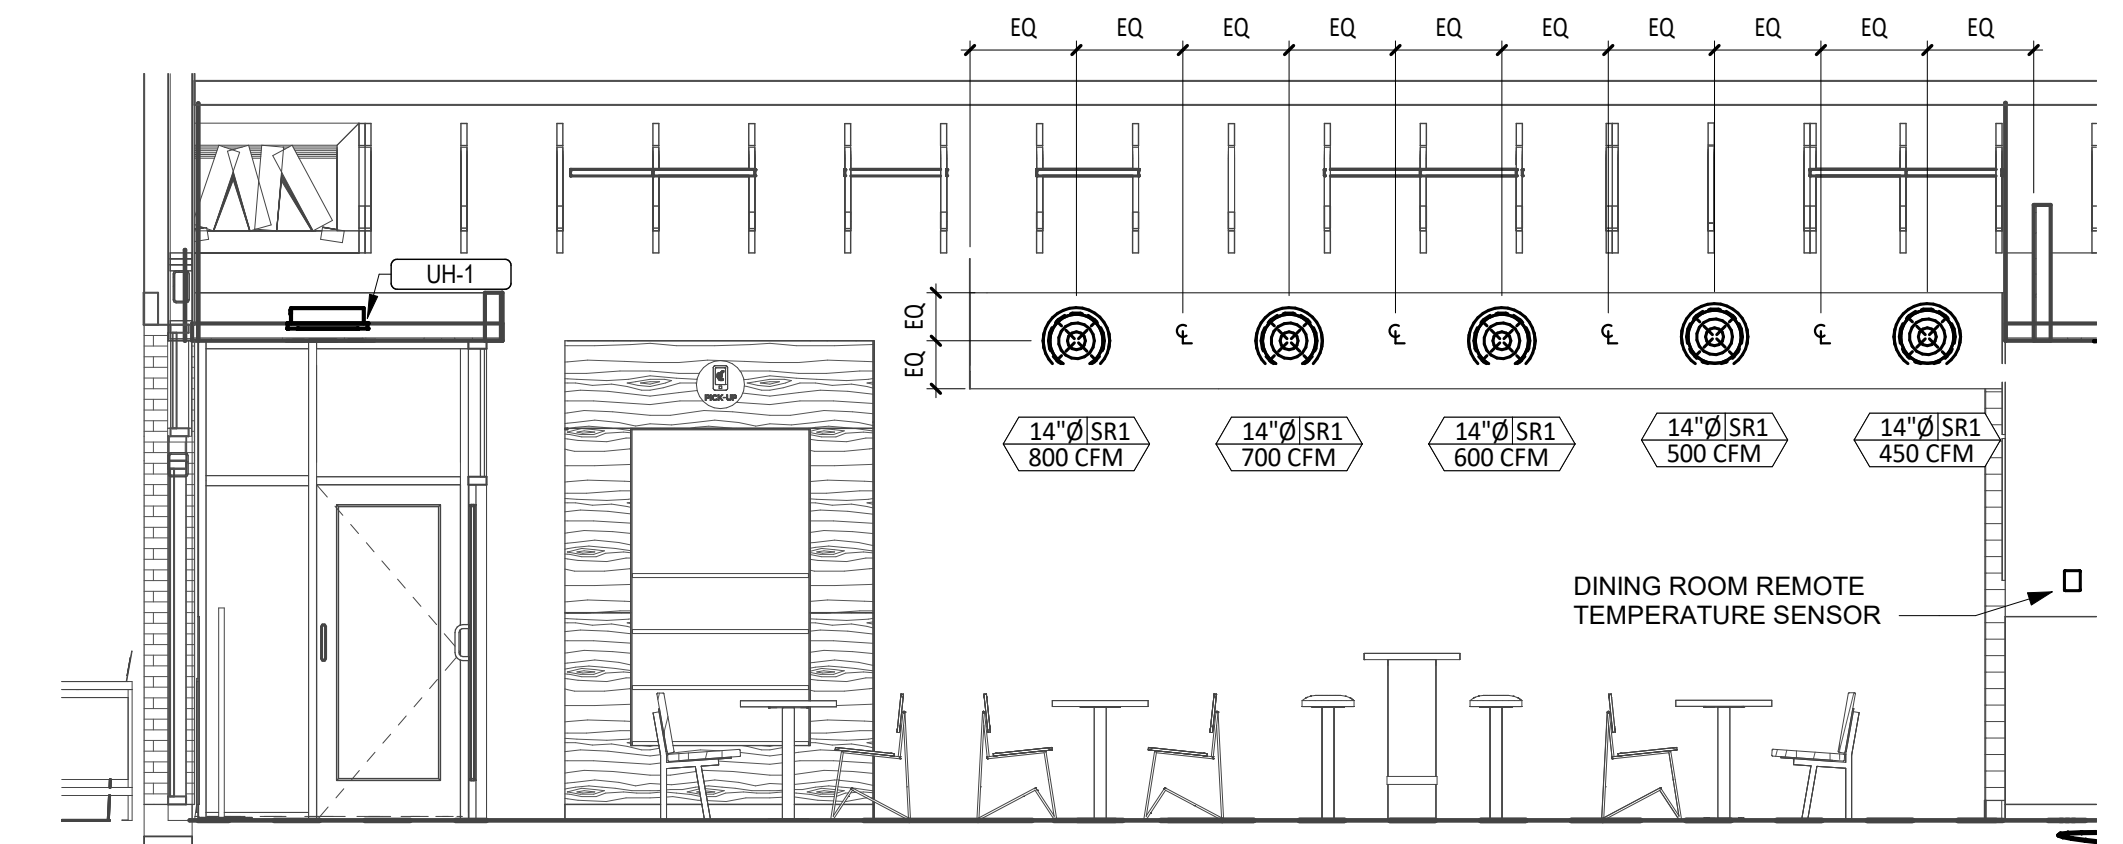


3 HVAC DINING ROOM SECTION
1/4" = 1'-0"

HVAC PLAN NOTES

- INSTALL REMOTE CONDENSING UNIT FOR WALK-IN COOLER ON ROOF AS DETAILED IN THE ARCHITECTURAL AND STRUCTURAL DRAWINGS. INSTALL REFRIGERANT LINE SET, THERMOSTATIC EXPANSION VALVE, SOLENOID VALVE, TEMPERATURE CONTROL, SIGHT GLASS, FILTER DRIER, PRESSURE CONTROL, LOW AMBIENT CONTROLS, AND WEATHERPROOF HOUSING. TRAP AND SLOPE REFRIGERANT LINES PER MANUFACTURER'S RECOMMENDATIONS. INSTALLATION SHALL COMPLY WITH ASHRAE/ANSI STANDARD 15. INSTALL THE REFRIGERANT LINE SET UNDER THE ROOF DECK TO WITHIN 3' OF THE CONDENSING UNIT. CUT 2-1/2" HOLE IN WALK-IN COOLER ROOF FOR REFRIGERANT LINE SET AND SEAL PER THE COOLER MANUFACTURER'S INSTALLATION INSTRUCTIONS AFTER LINE SET IS INSTALLED.
- INSTALL REMOTE CONDENSER FOR ICE MACHINE ON ROOF AS DETAILED IN THE ARCHITECTURAL AND STRUCTURAL DRAWINGS. INSTALL REFRIGERANT LINE SET, THERMOSTATIC EXPANSION VALVE, SOLENOID VALVE, TEMPERATURE CONTROL, SIGHT GLASS, FILTER DRIER, PRESSURE CONTROL, LOW AMBIENT CONTROLS, AND WEATHERPROOF HOUSING. TRAP AND SLOPE REFRIGERANT LINES PER MANUFACTURER'S RECOMMENDATIONS. SEAL PIPING PENETRATIONS THROUGH ROOF. INSTALLATION SHALL COMPLY WITH ASHRAE/ANSI STANDARD 15. INSTALL THE REFRIGERANT LINE SET UNDER THE ROOF DECK TO WITHIN 3' OF THE REMOTE CONDENSER. IF REFRIGERANT PIPING TO ICE MAKER IS EXPOSED TO PUBLIC VIEW CONCEAL WITHIN A STAINLESS STEEL SHROUD AS SHOWN IN THE ARCHITECTURAL DRAWINGS.
- INSTALL ROOFTOP EQUIPMENT PER MANUFACTURER'S INSTALLATION INSTRUCTIONS AND AS DETAILED IN THE ARCHITECTURAL AND STRUCTURAL DRAWINGS.
- INSTALL EXHAUST FAN EF-1 PER DETAIL 5/M700 AND AS DETAILED IN THE ARCHITECTURAL AND STRUCTURAL DRAWINGS. INSTALL GREASE VIROGUARD SYSTEM FURNISHED BY CHIPOTLE ON EXHAUST FAN, EF-1.
- PROVIDE SUPPLY DIFFUSER CONNECTION TO SUPPLY SYSTEM PER DETAIL 1/M700. TYPICAL.
- PROVIDE AUDIO/VISUAL REMOTE SMOKE DETECTOR ANNUNCIATOR WITH REMOTE KEY OPERATED RESET. WIRE A UNIT BACK TO EACH SMOKE DETECTOR. MOUNT UNIT 80" AFF. TYPICAL.
- INSTALL REME HALO AIR PURIFIER FURNISHED BY TUV IN RTU PER DETAIL 6/M700. SEE ELECTRICAL DRAWINGS FOR POWER CONNECTION INFORMATION. INSTALL UV WARNING STICKERS ON FACE OF ENCLOSURE PER DETAIL AND ON ANY RTU ACCESS DOOR(S) THROUGH WHICH THE REME HALO WOULD BE VISIBLE IF OPENED.
- MAINTAIN 10' CLEARANCE BETWEEN WATER HEATER FLUE TERMINATION AND OUTSIDE AIR INTAKES. MAINTAIN 10' CLEARANCE BETWEEN WATER HEATER COMBUSTION AIR INTAKE AND EXHAUST FAN EF-1 DISCHARGE. SEE PLUMBING DRAWINGS FOR MORE INFORMATION ON WATER HEATER FLUE AND COMBUSTION AIR TERMINATIONS.
- ADJUST SUPPLY REGISTERS SO THAT SUPPLY AIR HITS WALL ON OPPOSITE SIDE OF ROOM AT APPROXIMATELY 7' AFF WITH NO DRAFTS FELT IN THE DINING ROOM.

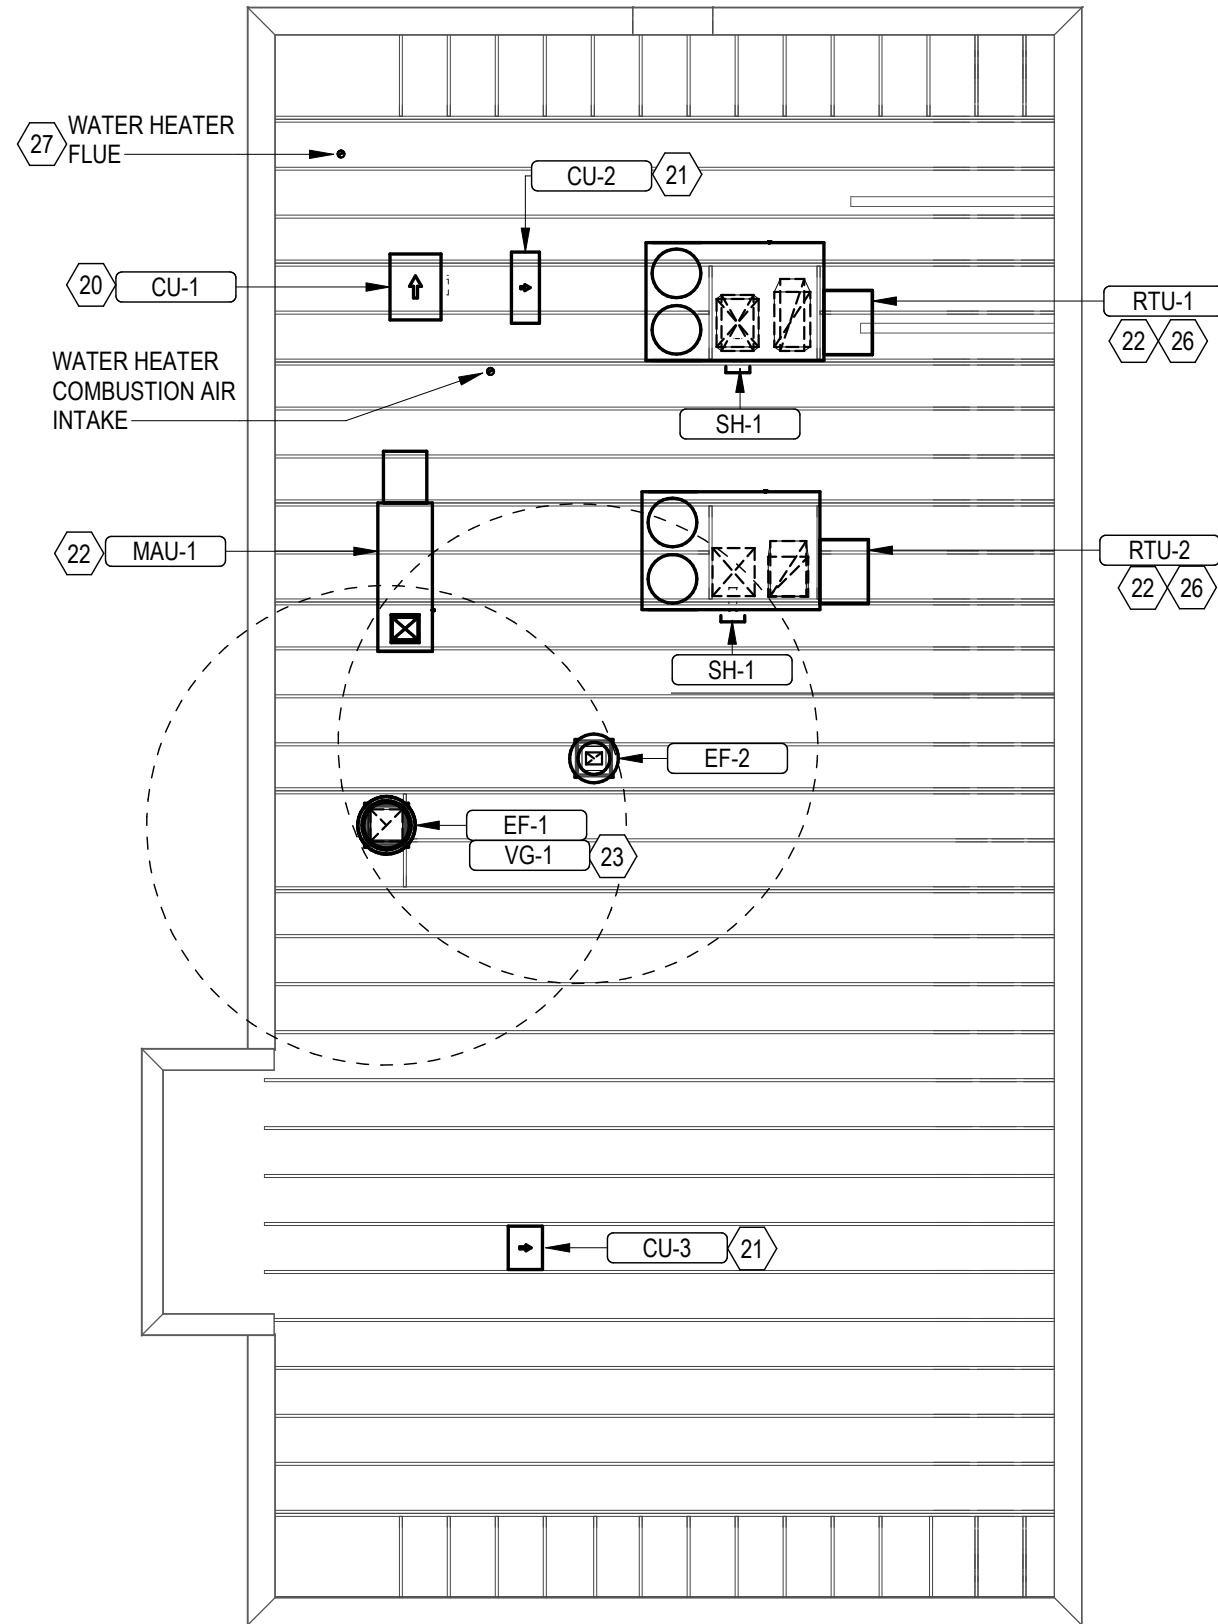


2 ROOF MECHANICAL PLAN
1/8" = 1'-0"

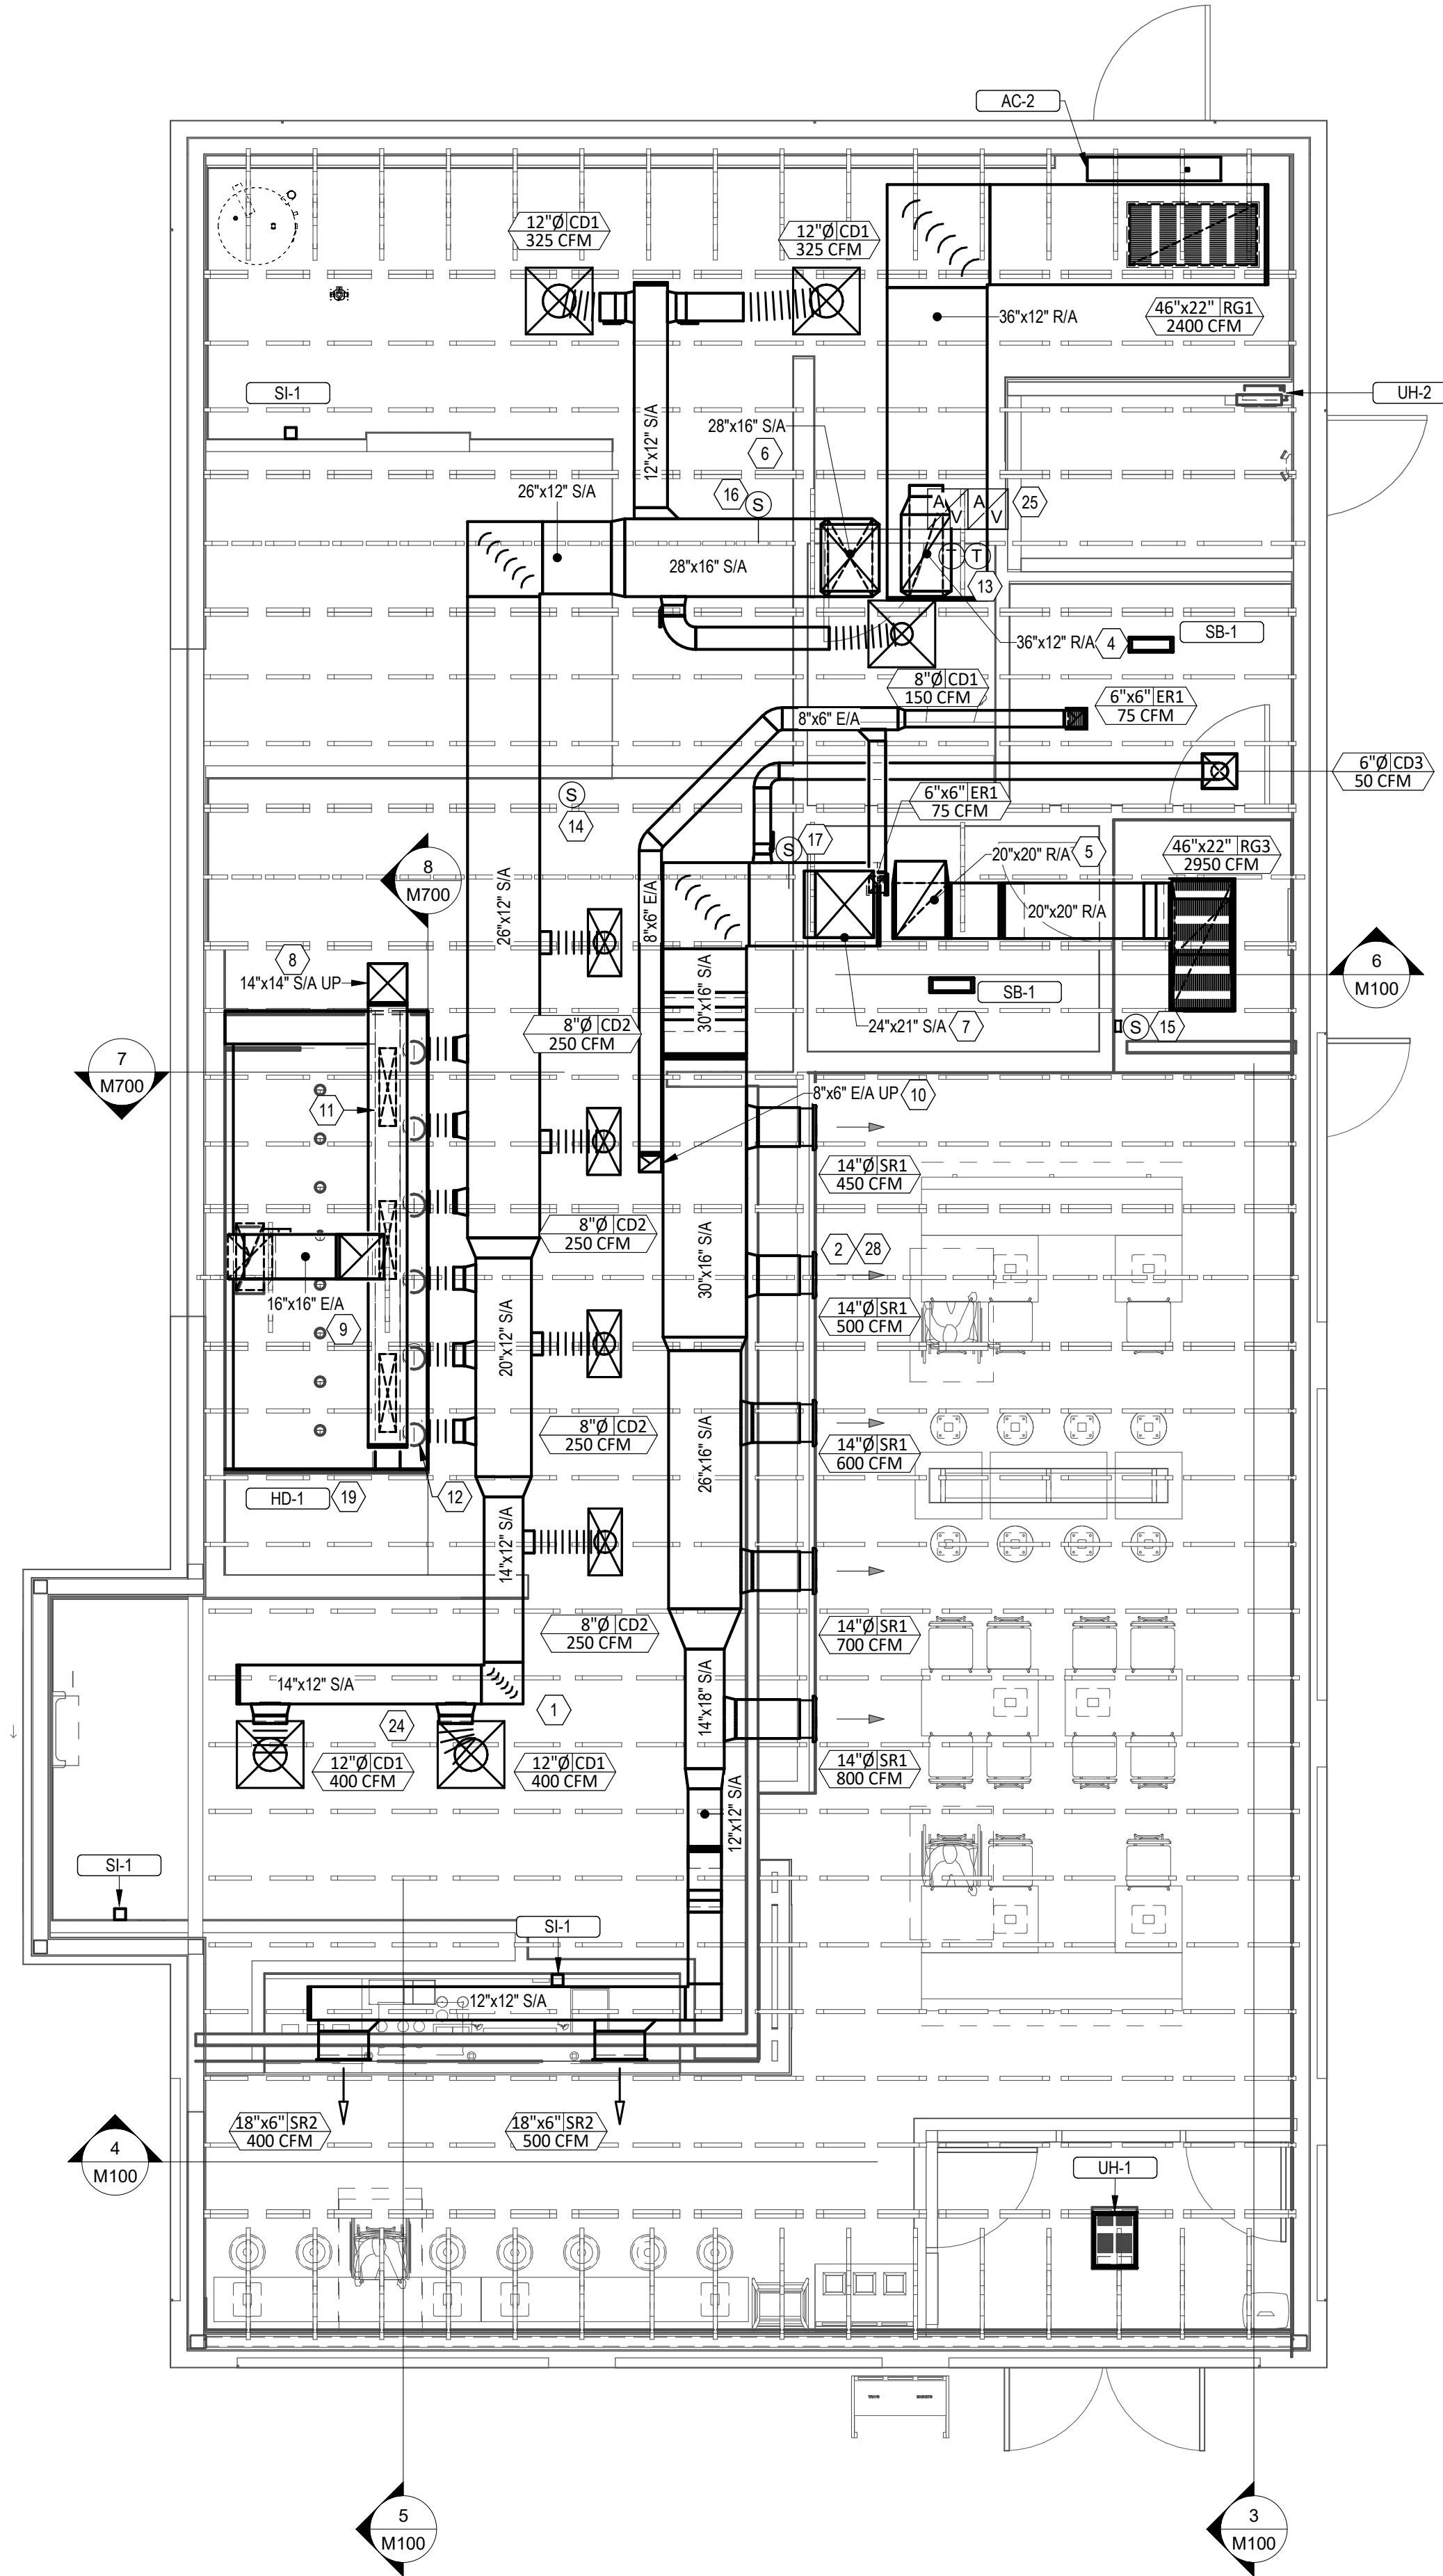

1 HVAC PLAN
1/4" = 1'-0"

Consultant:

AYRES
MECHANICAL, ELECTRICAL,
PLUMBING (MEP)
1700 West Highway 36 - Suite 700
Roseville, Minnesota 55113
(651) 639-9606 Fax (651) 639-9618
Project No. 81-0606

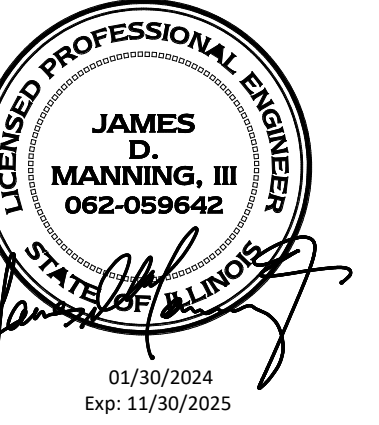

COPYRIGHT 2024
THIS DRAWING IS AN INSTRUMENT OF SERVICE AND
AS SUCH REMAINS THE PROPERTY OF CHIPOTLE
MEXICAN GRILL, INC. PERMISSION FOR USE OF THIS
DOCUMENT IS LIMITED AND CAN BE EXTENDED ONLY
BY WRITTEN AGREEMENT WITH CHIPOTLE MEXICAN
GRILL, INC.



CHIPOTLE MEXICAN GRILL, INC.
PO BOX 182566
COLUMBUS, OH 43218-2566
(614) 318-2400
www.chipotle.com

STORE NO.: 5037

"HUNTLEY"
12990 ROUTE 47, LOT 4B
HUNTLEY, IL 60142

Issue Record:

01/30/2024	PERMIT SUBMITTAL
03/15/2024	BID SET
05/03/2024	CONSTRUCTION SET

Revisions:

Drawn: RLD
Checked: LAO

Project No.

2023-0175

Contents:

HVAC PLAN

M100

AIR BALANCE SCHEDULE				
TAG	SUPPLY FLOW	RETURN FLOW	EXHAUST FLOW	SUBTOTAL
EF-1	0 CFM	0 CFM	2,550 CFM	-2,550 CFM
EF-2	0 CFM	0 CFM	150 CFM	-150 CFM
MAU-1	1,300 CFM	0 CFM	0 CFM	1,300 CFM
RTU-1	3,400 CFM	2,900 CFM	0 CFM	500 CFM
RTU-2	4,000 CFM	3,000 CFM	0 CFM	1,000 CFM
NET PRESSURIZATION				100 CFM

AIR TERMINAL SCHEDULE										
TAG	DESCRIPTION	FACE SIZE	MATERIAL	FINISH	MOUNTING	FURNISHED BY	INSTALLED BY	BASIS FOR DESIGN		NOTES
								MANUFACTURER	MODEL	
CD1	PERFORATED CEILING DIFFUSER	24" X 24"	ALUMINUM	WHITE	LAY-IN CEILING	GC	GC	NAILOR	4320A TYPE L	PROVIDE WITH INTEGRAL OBD
CD2	PERFORATED DIFFUSER WITH DEFLECTORS	24" X 12"	ALUMINUM	WHITE	LAY-IN CEILING	GC	GC	NAILOR	4320A TYPE L	PROVIDE WITH INTEGRAL OBD, REMOVE 4 -WAY DEFLECTORS
CD3	PERFORATED CEILING DIFFUSER	12" X 12"	ALUMINUM	WHITE	SURFACE MOUNT	GC	CG	NAILOR	4320A TYPE S	PROVIDE WITH INTEGRAL OBD
ER1	PERFORATED CEILING EXHAUST	12" X 12"	ALUMINUM	WHITE	SURFACE MOUNT	GC	CG	NAILOR	4330R TYPE S	PROVIDE INTEGRAL OBD
RG1	PERFORATED CEILING RETURN	48" X 24"	ALUMINUM	WHITE	LAY-IN CEILING	GC	GC	NAILOR	4330R TYPE L	
RG3	PERFORATED CEILING RETURN	48" X 24"	ALUMINUM	WHITE	SURFACE MOUNT	GC	GC	NAILOR	4330R TYPE S	
SR1	ADJUSTABLE TURBO NOZZLE	SEE NECK SIZE	ALUMINUM	WHITE	WALL	GC	GC	AIR CONCEPTS	ANR-14	PROVIDE WITH CONCEALED MOUNTING AND FACE-ACCESSIBLE OBD
SR2	DOUBLE DEFLECTION SUPPLY REGISTER	SEE NECK SIZE	ALUMINUM	WHITE	WALL	GC	GC	NAILOR	51DH	PROVIDE WITH INTEGRAL OBD

FAN SCHEDULE												
TAG	DESCRIPTION	AIRFLOW	ESP	WEIGHT	ELECTRICAL			FURNISHED BY	INSTALLED BY	BASIS FOR DESIGN		REMARKS
					MOTOR POWER	VOLT	PH			MANUFACTURER	MODEL NO.	
EF-1	UPBLAST UL762 EXHAUST FAN	2550 CFM	1.20 in-wg	400 lb	2.00 hp	208 V	3	HS	GC	CAPTIVE-AIRE	DU180HFA	DIRECT DRIVE UL762 UPBLAST EXHAUST FAN FURNISHED WITH WEATHERPROOF DISCONNECT AND VENTED ROOF CURB
EF-2	DOWNBLAST RESTROOM EXHAUST FAN	150 CFM	0.60 in-wg	100 lb	0.25 hp	120 V	1	HS	GC	CAPTIVE-AIRE	DR12HFA	DIRECT DRIVE DOWNBLAST RESTROOM EXHAUST FAN FURNISHED WITH INTEGRAL DISCONNECT, SPEED CONTROL, BACKDRAFT DAMPER, AND CURB

VIROGUARD							
TAG	COUNT	DESCRIPTION	DUCT CONNECTION SIZE	FAN	FURNISHED BY	INSTALLED BY	BASIS FOR DESIGN
VG-1	1	VIROGUARD HOOD EXHAUST FAN ROOFTOP CONTAINMENT SYSTEM	16X16	CAPTIVE-AIRE DU180HFA	TDC	TDC	ENVIROMATIC

AIR CURTAIN SCHEDULE										
TAG	DESCRIPTION	AIRFLOW	WEIGHT	HEATING ELEMENT	MOTOR POWER	V/P/H	FURNISHED BY	INSTALLED BY	MANUFACTURER	Model
AC-2	UNHEATED AIR CURTAIN	1,360 CFM	42 lb	0 kW	0.2 hp	120/1/60	GC	GC	BERNER	SLC07-1048AA
		PROVIDE WITH DOOR LIMIT SWITCH AND WALL MOUNTING BRACKETS.								

CONDENSING UNIT SCHEDULE													
TAG	DESCRIPTION	NUMBER OF		REFRIGERANT		WEIGHT	MOCp	ELECTRICAL			FURNISHED BY	INSTALLED BY	REMARKS
		COMPRESSORS	CIRCUITS	TYPE	CHARGE			FLA	VOLT	PH			
CU-1	CONDENSING UNIT - WALK-IN COOLER	1	1	R-404A	10.40 lb	250 lb	15 A	9 A	208 V	3	WCS	GC	FURNISHED WITH WALK-IN COOLER
CU-2	REMOTE CONDENSER - LOW CAPACITY ICE MAKER	0	1	R-404A	11.46 lb	100 lb	0 A	0 A	120 V	1	KES	GC	FURNISHED WITH ICE MAKER
CU-3	REMOTE CONDENSER - SODA MACHINE ICE MAKER	0	1	R-404A	3.86 lb	100 lb	0 A	0 A	120 V	1	KES	GC	FURNISHED WITH ICE MAKER

MAKEUP AIR UNIT SCHEDULE														
TAG	DESCRIPTION	AIRFLOW	ESP	HEATING			WEIGHT	ELECTRICAL			FURNISHED BY	INSTALLED BY	BASIS FOR DESIGN	
				INPUT	OUTPUT	EAT(db)		MOTOR POWER	VOLT	PH			MANUFACTURER	MODEL NO.
MAU-1	DIRECT-FIRED MAKEUP AIR UNIT	1300 CFM	0.50 in-wg	225000 Btu/h	220000 Btu/h	-3.8 °F	650 lb	1.00 hp	208 V	3	HS	GC	CAPTIVE-AIRE	A1-D-250-1SD
		12.5:1 MAX TURNDOWN. FURNISHED WITH DISCONNECT, ROOF CURB, SCREEN INTAKE, AND WASHABLE ALUMINUM FILTERS												

KITCHEN HOOD SCHEDULE																
TAG	DESCRIPTION	MAX COOKING TEMP	EXHAUST PLENUM						NO. OF LIGHT FIXTURES	WEIGHT	FURNISHED BY	INSTALLED BY	BASIS FOR DESIGN		REMARKS	
			AIRFLOW	ESP	DUCT COLLARS			LENGTH					WIDTH	MANUFACTURER		MODEL NO.
					NO.	WIDTH	LENGTH									
HD-1	TYPE I CANOPY HOOD WITH PERFORATED MAU AND AC SUPPLY PLENUMS	600.0 °F	2550 CFM	0.97 in-wg	1	10"	2'-0"	12'-9"	4'-3"	8	1150 lb	HS	GC	MANUFACTURER Captive-Aire	5424 ND-2-ACPSP-F	MATL: 18 GA. TYPE430 SS. FURNISHED WITH VERTICAL END PANELS, VAPORPROOF INCANDESCENT LIGHT FIXTURES, 16" TALL HE SS FILTERS, INTEGRAL UTILITY CABINET, KITCHEN EXHAUST SUPPRESSION SYSTEM, DUCT COLLAR TEMPERATURE SENSOR, PREWIRE PACKAGE, SPARE FIRE SYSTEM DRY CONTACT, AND 4-POLE 20A CONTACTOR.

ROOFTOP UNIT SCHEDULE																												
TAG	DESCRIPTION	NOMINAL CAPACITY	EER	AIRFLOW			NET COOLING CAPACITY					HEATING CAPACITY			NUMBER OF		REFRIGERANT		WEIGHT	ELECTRICAL			FURNISHED BY	INSTALLED BY	BASIS FOR DESIGN		REMARKS	
				TOTAL	OA	ESP	TOTAL	SENSIBLE	EAT(db)	EAT(wb)	COND. EAT	INPUT	CAP	EAT(db)	COMPRESSORS	CIRCUITS	TYPE	CHARGE		MOC	FLA	VOLT			PH	MANUFACTURER		MODEL NO.
RTU-1	KITCHEN ROOFTOP UNIT	8.5 ton	12	3400 CFM	500 CFM	0.80 in-wg	100100 Btu/h	68600 Btu/h	77.3 °F	64.4 °F	95 °F	180000 Btu/h	144000 Btu/h	58.6 °F	2	2	R-410A	8.1/7.9 lb	1350 lb	60 A	48.3 A	208 V	3	HES	GC	YORK	ZJ102	FURNISHED WITH COMP. ENTHALPY ECON., BAROMETRIC RELIEF, RET. SMOKE DETECTOR W/ REMOTE KEYED ANNUNCIATOR/RESET, M.O.D., MERV-8 FILTERS, CURB, HAIL GUARD, TOOLLESS HINGED ACCESS PANELS, DISCONNECT, & UNIT-MOUNTED CONVENIENCE RECEPTACLE
RTU-2	DINING ROOM ROOFTOP UNIT	10.0 ton	12	4000 CFM	1000 CFM	0.80 in-wg	118100 Btu/h	89300 Btu/h	78.9 °F	65.7 °F	95 °F	240000 Btu/h	192000 Btu/h	50.7 °F	2	2	R-410A	7.8/7.6 lb	1350 lb	50 A	44.9 A	208 V	3	HES	GC	YORK	ZJ120	FURNISHED WITH COMP. ENTHALPY ECON., BAROMETRIC RELIEF, RET. SMOKE DETECTOR W/ REMOTE KEYED ANNUNCIATOR/RESET, M.O.D., MERV-8 FILTERS, CURB, HAIL GUARD, TOOLLESS HINGED ACCESS PANELS, DISCONNECT, & UNIT-MOUNTED CONVENIENCE RECEPTACLE

ASHRAE 62.1 Ventilation Calculations									
Ventilation Equipment Identity	Location		Occupancy Category	Occupants or Units	Ventilation Rate Procedure				Required Outdoor Air Intake Flow, Vot
	No.	Name			Design	Area, Az	Breathing Zone Outdoor Airflow, Voz	Zone Air Distribution Effectiveness, Ez	
RTU-1	104	POS	Restaurant dining rooms	15.6	224 SF	158 CFM	0.8		197 CFM
RTU-1	106	SERVING	Kitchen (cooking)	2.8	138 SF	37 CFM	0.8		47 CFM
RTU-1	107	COOKING	Kitchen (cooking)	5.6	278 SF	75 CFM	0.8		94 CFM
RTU-1	108	KITCHEN	Kitchen (cooking)	6.4	320 SF	86 CFM	0.8		108 CFM
RTU-1	109	OFFICE	Office space	0.2	44 SF	4 CFM	0.8		5 CFM
RTU-1					1004 SF				450 CFM
RTU-2	100	MAIN ENTRY	Main entry lobbies	0.6	63 SF	7 CFM	0.8		9 CFM
RTU-2	101	DINING	Restaurant dining rooms	36.0	515 SF	363 CFM	0.8		454 CFM
RTU-2	102	UTENSIL	Restaurant dining rooms	2.4	34 SF	24 CFM	0.8		30 CFM
RTU-2	103	PASSAGE	Corridors	0.0	33 SF	2 CFM	0.8		3 CFM
RTU-2	105	ORDERING	Restaurant dining rooms	4.8	69 SF	48 CFM	0.8		61 CFM
RTU-2					714 SF				566 CFM
Grand total: 10					1718 SF				1006 CFM

CONTROL FUNCTIONS

- A. THE MAIN COOKING EXHAUST FAN AND ROOFTOP HEAP PUMP UNITS SHALL BE INTERLOCKED TO OPERATE TOGETHER. THIS CONTROL CIRCUIT IS ACTIVATED BY A SWITCH AND INCLUDES A FIRE PROTECTION OVERRIDE.
- B. THE TEMPERATURE IN EACH ZONE IS CONTROLLED BY SPACE TEMPERATURE SENSORS CONNECTED TO THE THERMOSTATS LOCATED IN THE OFFICE. ALL ZONES SHALL OPERATE WITH CONTINUOUS FAN OPERATION DURING OCCUPIED TIMES AND INTERMITTENTLY AS NEEDED TO MAINTAIN SET POINTS DURING UNOCCUPIED TIMES. OUTSIDE AIR DAMPERS SHALL BE OPEN CONTINUOUSLY WHEN EITHER IN OCCUPIED MODE OR WHEN THE HOOD SYSTEM IS ON AND SHALL BE CLOSED DURING UNOCCUPIED PERIODS.
- C. THE THERMOSTATS SHALL DETERMINE OCCUPIED/UNOCCUPIED STATUS BASED ON THE SCHEDULE IN THE ENERGY MANAGEMENT SYSTEM.

Consultant:

AYRES
MECHANICAL, ELECTRICAL,
PLUMBING (MEP)
1700 West Highway 36 - Suite 700
Roseville, Minnesota 55113
(651) 639-9606 Fax (651) 639-9618
Project No. 81-0606



COPYRIGHT 2024
THIS DRAWING IS AN INSTRUMENT OF SERVICE AND AS SUCH REMAINS THE PROPERTY OF CHIPOTLE MEXICAN GRILL, INC. PERMISSION FOR USE OF THIS DOCUMENT IS LIMITED AND CAN BE EXTENDED ONLY BY WRITTEN AGREEMENT WITH CHIPOTLE MEXICAN GRILL, INC.



STORE NO.: 5037
"HUNTLEY"
12990 ROUTE 47, LOT 4B
HUNTLEY, IL 60142

Issue Record:	
01/30/2024	PERMIT SUBMITTAL
03/15/2024	BID SET
05/03/2024	CONSTRUCTION SET

Revisions:	
.03/07/24	CITY COMMENTS
.05/03/24	CONSTRUCTION

Drawn:	Checked:
RLD	LAO

Project No.

2023-0175

Contents:

HVAC SCHEDULES

M600


Diagram illustrating the ET-1C system components and their mounting:

- EF-1**: End Effector (Top component)
- VG-1**: Vision Gripper (Middle component)
- 16"x16" E/A**: End Effector Armature (Base plate)

The diagram shows the EF-1 and VG-1 components mounted on the 16"x16" E/A base plate. The ET-1C system is shown in a perspective view, highlighting the mounting structure and the components.

- MAINTAIN SYMMETRY IN GREASE EXHAUST DUCT'S TRANSITION TO THE EXHAUST RISER

9 HOOD EXHAUST ISOMETRIC
M700 NOT TO SCALE

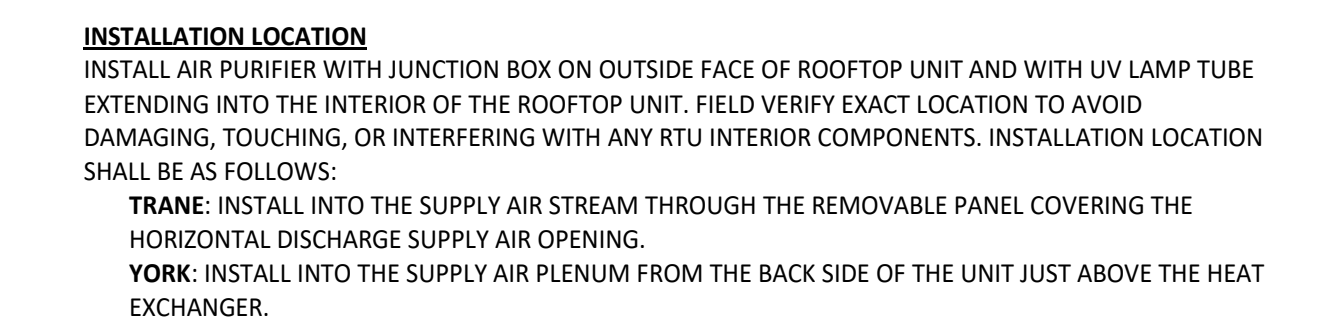


6 UV AIR PURIFIER INSTALLATION
M700 NOT TO SCALE


INSTALL VERTICAL END PANELS AT EACH END OF HOOD AS SHOWN. HOOD IS UL-LISTED FOR 0" OVERHANG WHEN USED WITH VERTICAL END PANELS.

8 HOOD ELEVATION
M700 NOT TO SCALE

7 DUCT SECTION AT HOOD
M700 NOT TO SCALE

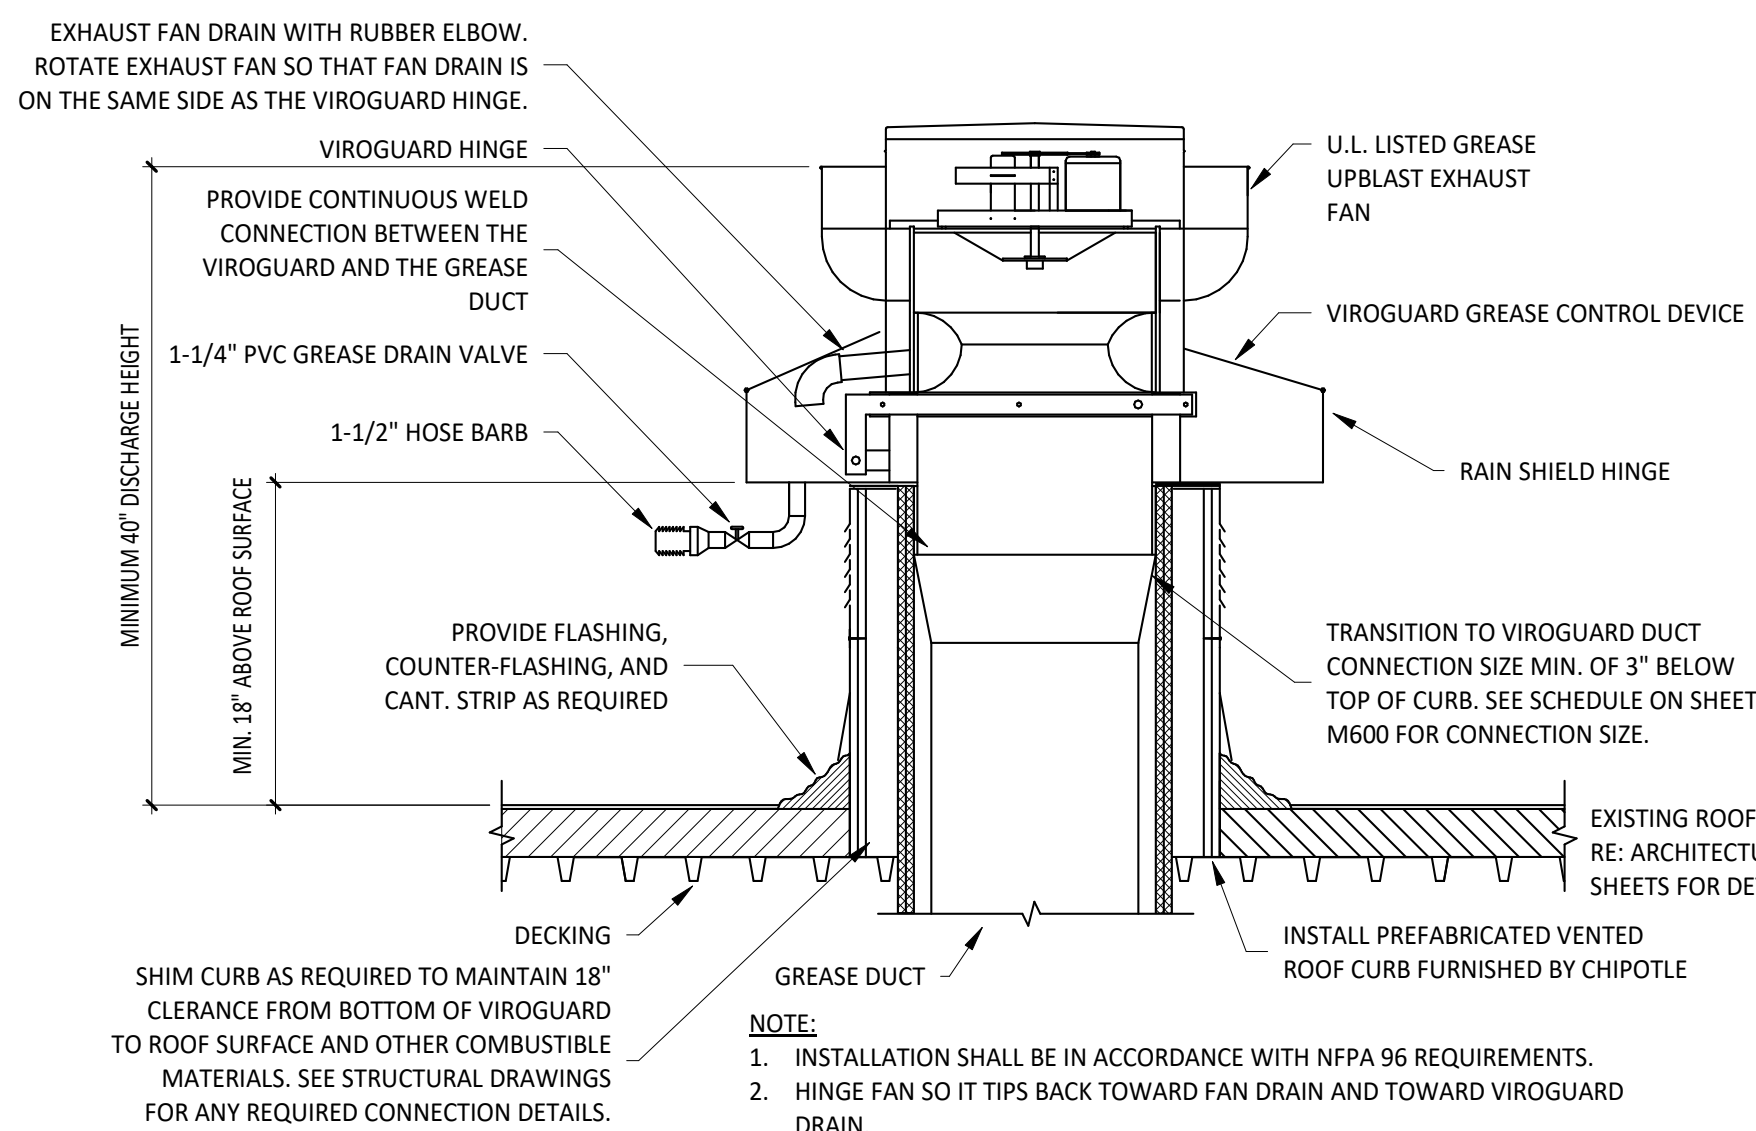


5 GREASE EXHAUST FAN
M700 NOT TO SCALE

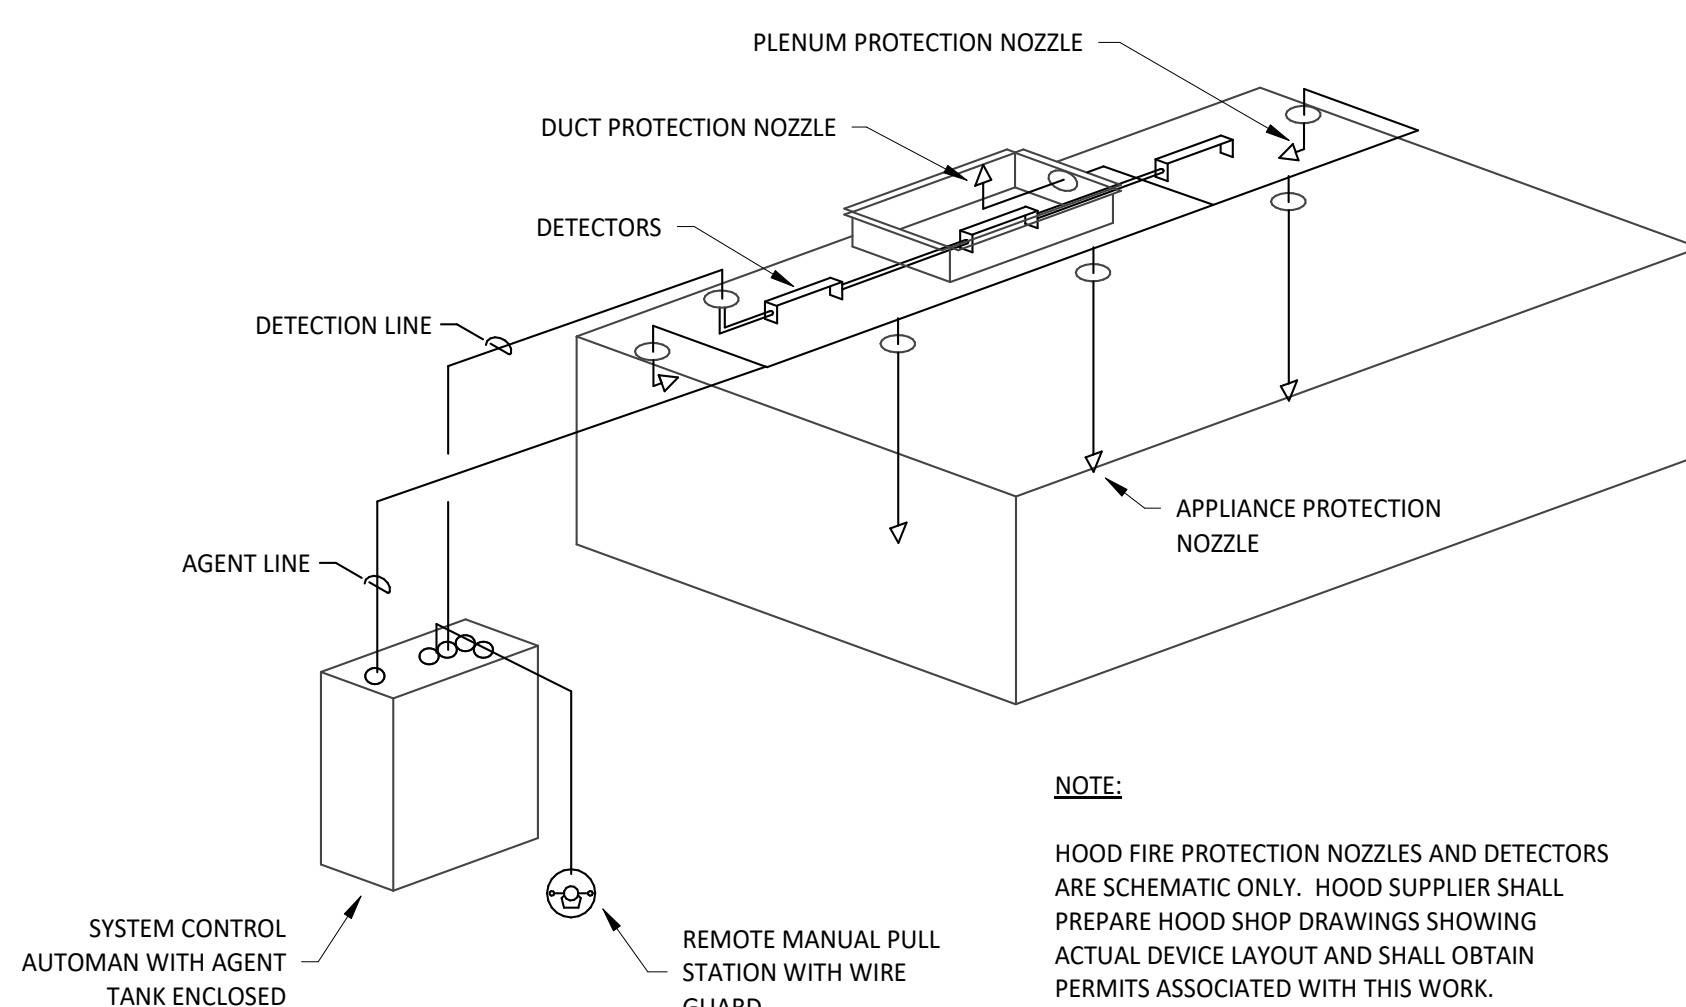


4 FIRE SUPPRESSION SYSTEM SCHEMATIC
M700 NOT TO SCALE


1. THERMAL CERAMICS FIREMASTER FASTWRAP XL IS TESTED TO ASTM E2336 AND UL LISTED PER HNTK.G18 TO PROVIDE ZERO CLEARANCE TO COMBUSTIBLES AND TO PROVIDE A 1- OR 2- HOUR ENCLOSURE, THROUGH PENETRATIONS FIRESTOP SYSTEMS ARE TESTED IN ACCORDANCE WITH ASTM E 814 (UL 1479). ICC CODE EVALUATION PER REPORT UL 14229-01.
2. COMPLIANT TO THE FOLLOWING CODES:
 - NFPA 96
 - INTERNATIONAL MECHANICAL CODES
 - UNIFORM MECHANICAL CODE
 - CALIFORNIA MECHANICAL CODE
3. INSULATION APPLIED IN TWO LAYERS WITH TIGHT COMPRESSION JOINT ON BOTH LAYERS AT ALL JOINTS.
4. MINIMUM 16 GAUGE CARBON STEEL (OR 18 GAGE STAINLESS STEEL) RECTANGULAR OR ROUND GREASE EXHAUST DUCT
5. INSTALL UL LISTED AND LIQUID TIGHT THERMAL CERAMICS FASTDOOR XL ACCESS DOORS, OR ALTERNATE DOOR UL LISTED PER UL1978, AT ALL CHANGES IN DIRECTION AND AT MINIMUM EVERY 20 FT ON HORIZONTAL RUNS.
6. SUPPORT HANGER SYSTEMS DO NOT NEED TO BE WRAPPED PROVIDED THE HANGER RODS ARE MINIMUM OF 3/8 IN. DIAMETER AND THE SUPPORTS ARE MINIMUM 2 X 2 X 1/8 IN. STEEL ANGLE OR 5/16 IN. DIA. EQUIVALENT SUPPORT SYSTEM.
7. THERMAL CERAMICS DUCT WRAP SHALL BE INSTALLED DIRECTLY ONTO THE DUCT AND APPLIED FROM THE HOOD CONNECTION TO THE CONNECTION TO THE FAN.
8. THERMAL CERAMICS DUCT ENCLOSURE SYSTEM SHALL BE INSTALLED IN STRICT ACCORDANCE WITH MANUFACTURERS INSTRUCTIONS AND UL LISTINGS.

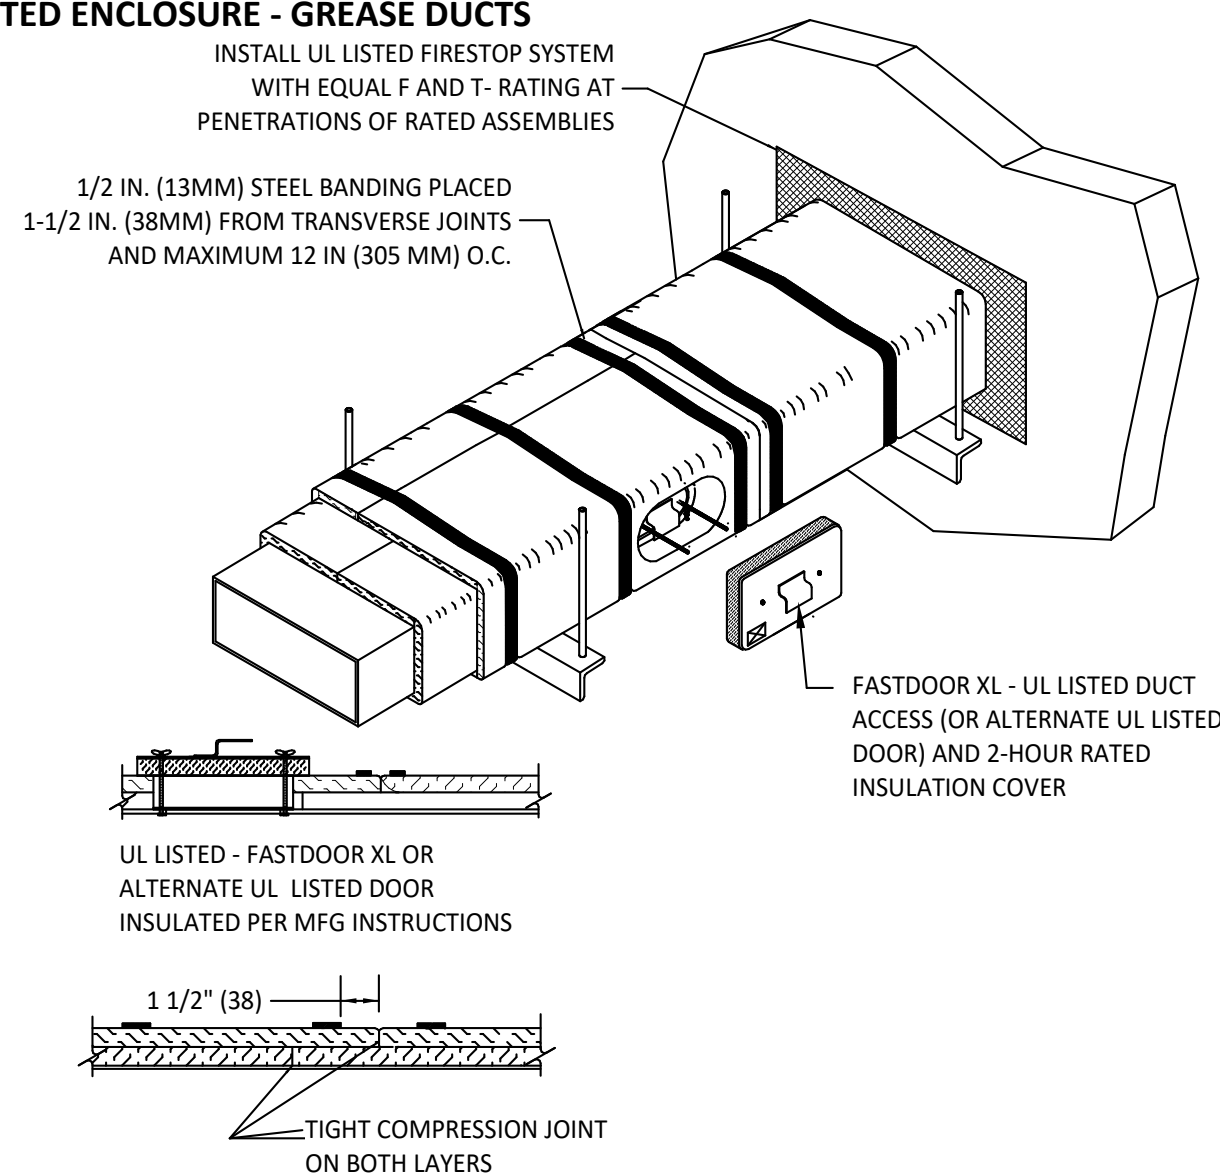

3 FIREMASTER DUCT WRAP - UL HNKT-G18
M700 NOT TO SCALE

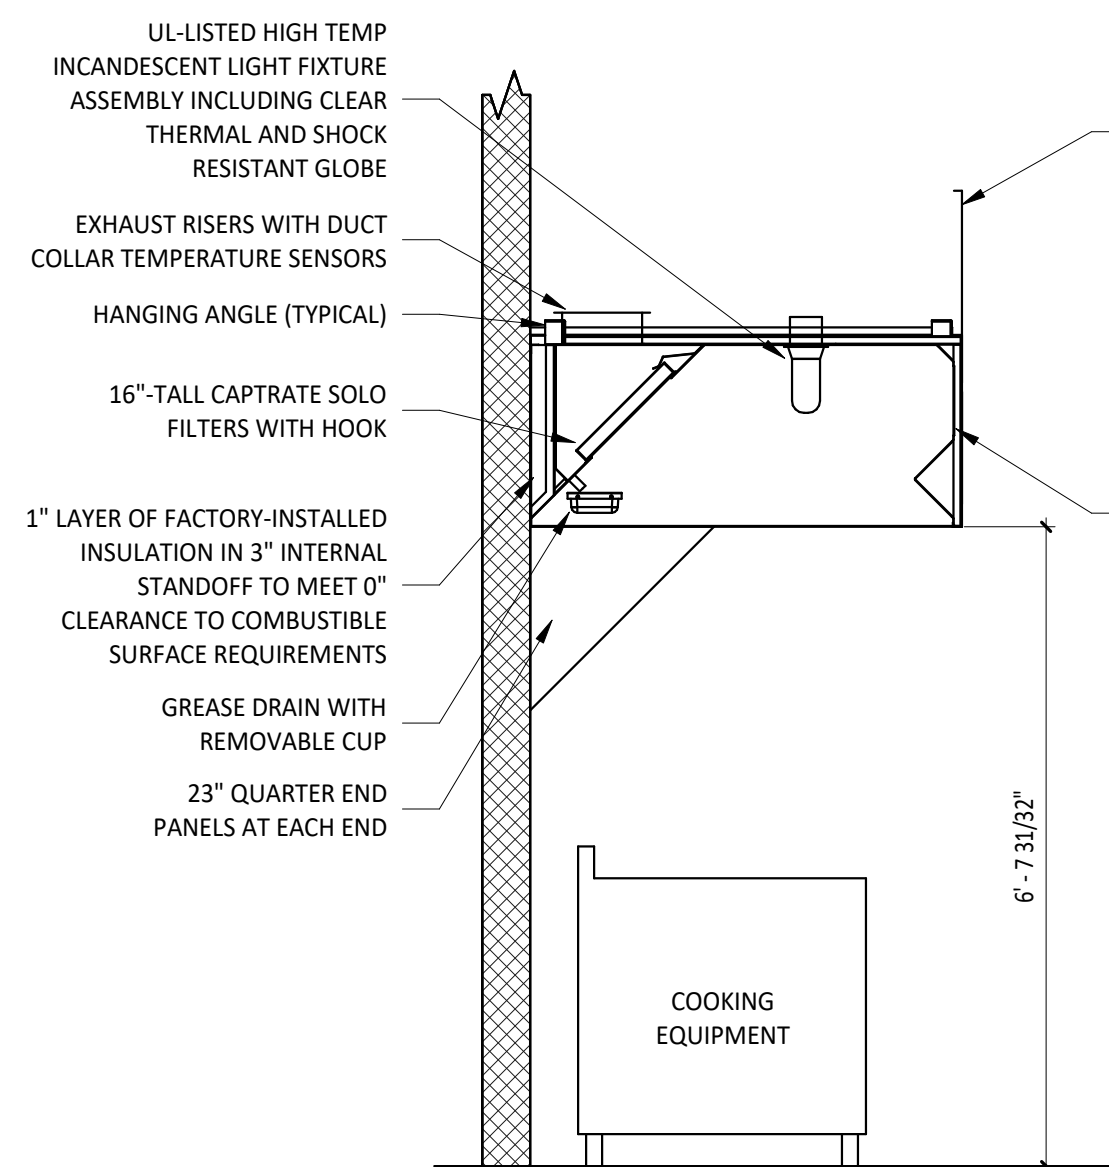


2 HOOD SECTION VIEW
M700 NOT TO SCALE

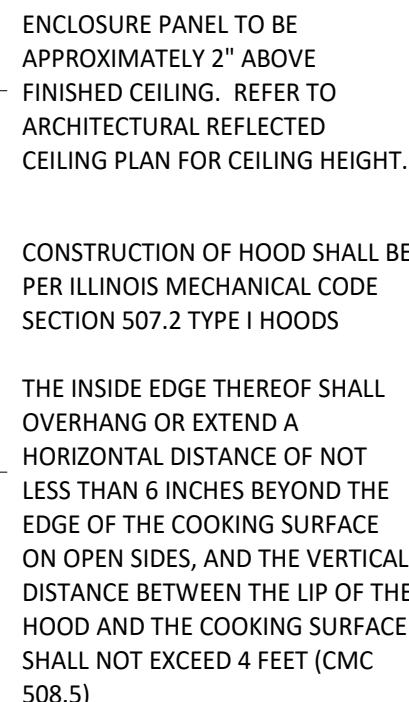

CONSTRUCTION OF HOOD SHALL BE PER ILLINOIS MECHANICAL CODE SECTION 507.2 TYPE I HOODS

THE INSIDE EDGE THEREOF SHALL OVERHANG OR EXTEND A HORIZONTAL DISTANCE OF NOT LESS THAN 6 INCHES BEYOND THE EDGE OF THE COOKING SURFACE ON OPEN SIDES, AND THE VERTICAL DISTANCE BETWEEN THE LIP OF THE HOOD AND THE COOKING SURFACE SHALL NOT EXCEED 4 FEET (CMC 508.5)

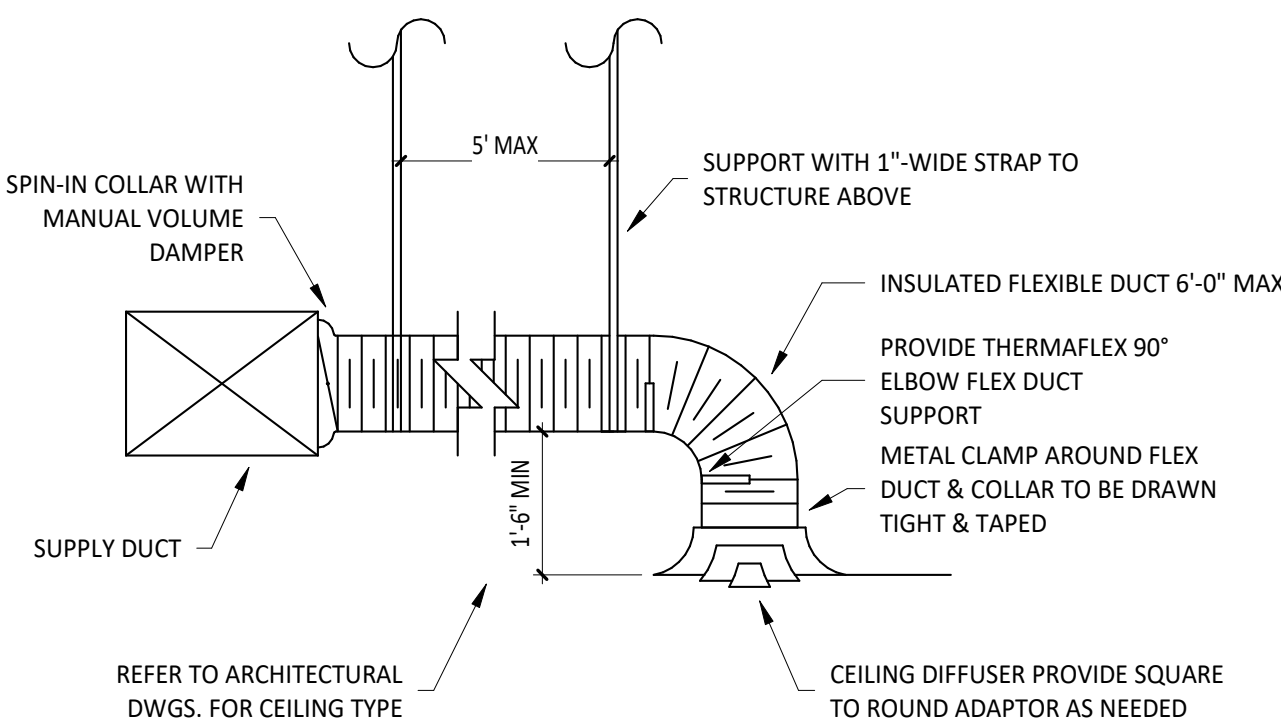

NOTE:
1. METHOD OF INSTALLATION FOR AIRTIGHT SEAL IS TYPICAL FOR ALL
FLEX CONNECTIONS TO AIR DISTRIBUTION DEVICES.

DIFFUSER CONNECTION
NOT TO SCALE

SECTION 15055 - COMMON PIPING REQUIREMENTS

- PART 1 - GENERAL
- A. SECTION REQUIREMENTS
1. Comply with the requirements of the Building Code and the local authority having jurisdiction.
- PART 2 - PRODUCTS
- 2.1 SUPPORTING DEVICES
- A. Hanger and Pipe Attachments: Factory fabricated with galvanized coatings; nonmetallic coated for hangers in direct contact with copper tubing.
- B. Building Attachments: Powder actuated type, drive pin attachments with pullout and shear capacities appropriate for supported loads and building materials; UL listing and FM approval for fire protection systems.
- C. Mechanical Anchor Fasteners: Insert-type attachments with pullout and shear capacities appropriate for supported loads and building materials; UL listing and FM approval for fire protection systems.
- PART 3 - EXECUTION
- 3.1 INSTALLATION
- A. Install piping free of sags and bends.
- B. Install fittings for changes in direction and branch connections.
- C. Install sleeves for pipes passing through concrete and masonry walls, gypsum board partitions, and concrete floor and roof slabs.
- D. Exterior Wall, Pipe Penetrations: Mechanical sleeve seals installed in steel or cast iron pipes for wall sleeves.
- E. Fire Barrier Penetrations: Seal pipe penetrations with through-penetration firestop systems.
- F. Install unions adjacent to each valve and at final connection to each piece of equipment.
- G. Install dielectric unions and flanges to connect piping materials of dissimilar metals in gas piping.
- H. Install dielectric coupling and nipple fittings to connect piping materials of dissimilar metals in water piping.
- I. Provide full ring escutcheons at plumbing penetrations through walls or ceilings. Tightly seal escutcheons to the adjacent surface.
- 3.2 HANGERS AND SUPPORTS
- A. Install building attachments within concrete or to structural steel. Install additional attachments at concentrated loads, including valves, flanges, guides, strainers, expansion joints, and at changes in direction of piping.
- B. Install powder actuated drive pin fasteners in concrete after concrete is cured. Do not use in lightweight concrete or in slabs less than 4 inches thick.
- C. Install mechanical anchor fasteners in concrete after concrete is cured. Do not use in lightweight concrete or in slabs less than 4 inches thick.
- D. Support fire protection system piping independent of other piping.
- E. Load Distribution: Install hangers and supports so piping live and dead loading and stresses from movement will not be transmitted to connected equipment.
- END OF SECTION 15055

SECTION 15080 - MECHANICAL INSULATION

- PART 1 - GENERAL
- 1.1 SECTION REQUIREMENTS
- A. Submittals: None.
- B. Quality Assurance: Labeled with maximum flame-spread rating of 25 and maximum smoke developed rating of 50 according to ASTM E 84.
- PART 2 - PRODUCTS
- 2.1 PIPE INSULATION
- A. Preformed Glass Fiber Pipe Insulation: ASTM C 547, Class 1, with factory applied, all purpose, vapor retarder jacket.
- B. Polyolefin Pipe Insulation: Unicellular polyethylene, preformed pipe insulation. Comply with ASTM C 534, Type I, except for density.
- PART 3 - EXECUTION
- 3.1 INSTALLATION
- A. Install vapor barriers on insulated pipes with surface operating temperatures below 60 deg F.
- B. Insulate fittings, valves, and specialties.
- C. Seal vapor barrier penetrations for hangers, supports, anchors, and other projections.
- D. Coat glass fiber pipe insulation ends with vapor barrier coating.
- E. Roof Penetrations: Apply insulation for interior applications to a point even with the top of the roof flashing.
- F. Exterior Wall Penetrations: For penetrations of below grade exterior walls, terminate insulation flush with mechanical sleeve seal.
- G. Interior Walls and Partitions Penetrations: Apply insulation continuously through walls and partitions, except fire rated walls and partitions.
- H. Fire Rated Walls and Partitions Penetrations: Terminate insulation at penetrations through fire rated walls and partitions. Seal around penetration with through penetration firestop systems.
- I. Floor Penetrations: Terminate insulation at the underside of the floor assembly and at the floor support at top of floor. Seal around penetration with through penetration firestop systems.
- J. Glass Fiber Insulation Installation: Bond insulation to pipe with adhesive. Seal seams and joints with vapor barrier compound.
- K. Interior Piping System Applications: Insulate the following piping systems:
1. Domestic cold, hot, and recirculation water pipes.
2. Exposed sanitary drains and water supply pipes for public hand sinks.
3. Refrigerant piping.
- L. Do not apply insulation to the following systems, materials, and equipment:
1. Flexible connectors.
2. Fire protection piping systems.
3. Sanitary drainage and vent piping.
4. Chrome plated pipes and fittings, except for plumbing fixtures for the disabled.
5. Piping specialties, including air chambers, unions, strainers, check valves, plug valves, and flow regulators.
- M. Pipe Insulation Thickness Application Schedule: Insulate piping with the following materials and thicknesses:
1. Domestic Hot and Recirculation water pipes: 1-inch preformed glass fiber pipe insulation.
2. Domestic Cold Water: 1/2-inch preformed glass fiber pipe insulation.
3. P-Trap and Fixture Supplies for public hand sinks: ADA-compliant pre-formed insulation.
- END OF SECTION 15080

SECTION 15110 - VALVES

- PART 1 - GENERAL (Not Applicable)
- PART 2 - PRODUCTS
- 2.1 GENERAL DUTY VALVES
- A. End Connections: Threads shall comply with ANSI B1.20.1. Flanges shall comply with ANSI B16.1 for cast iron valves and ANSI B16.24 for bronze valves. Solder-joint connections shall comply with ANSI B16.18.
- B. Ball Valves: Rated for 150 psig saturated steam pressure, 400 psig WOG pressure; 2 piece construction; with bronze body, standard (or regular) port, chrome plated brass ball, replaceable "Teflon" or "TFE" seats and seals, blowout proof stem, and vinyl covered steel handle.
- C. Plug Valves: Rated at 150 psig WOG; bronze body, with straightaway pattern, square head, and threaded ends.
- D. Swing Check Valves: Class 125, cast bronze body and cap; with horizontal swing, Y-pattern, and bronze disc.
- E. Valves for Copper Tube: Solder ends, except provide threaded ends for heating hot water and low pressure steam service.
- F. Valves for Steel Pipe: Threaded ends.
- PART 3 - EXECUTION
- 3.1 INSTALLATION
- A. Use gate and ball valves for shutoff duty and ball for throttling duty.
- B. Locate valves for easy access and provide separate support where necessary.
- C. Install accessible valves for each fixture and item of equipment.
- D. Install valves in horizontal piping with stem at or above center of pipe.
- E. Install valves in a position to allow full stem movement.
- F. Install check valves for proper direction of flow in horizontal position with hinge pin level.
- END OF SECTION 15110

SECTION 15140 - DOMESTIC WATER PIPING

- PART 1 - GENERAL
- 1.1 SECTION REQUIREMENTS
- A. Performance Requirements: Unless otherwise indicated minimum pressure requirements for water piping are as follows:
1. Service Entrance Piping: 100 psig.
2. Domestic Water Piping: 80 psig.
- B. Comply with NSF 14 "Plastic Piping Components and Materials."
- C. Comply with NSF 61 "Drinking Water System Components -- Health Effects."
- PART 2 - PRODUCTS
- 2.1 PIPES AND TUBES (See Material Schedule on sheet P010 for where these materials are to be used)
- A. Hard Copper Tube: ASTM B 88, Types L and M, water tube, drawn temper.
- B. PVC Plastic, Water Pipe: ASTM D 1785, Schedule 80, plain ends.
- 2.2 FITTINGS
- A. Wrought Copper, Solder Joint Pressure Fittings: ASME B 16.22.
- B. Cast Copper Alloy, Solder Joint Pressure Fittings: ASME B 16.18.
- C. Bronze Flanges: ASME B 16.24, Classes 150 and 300.
- D. Copper Unions: ASME B 16.18, cast copper alloy body, hexagonal stock, with ball and socket joint, metal to metal seating surfaces, and solder joint, threaded, or solder joint and threaded ends. Threads complying with ASME B 1.20.1.
- E. PVC Plastic, Schedule 80, Socket Type Pipe Fittings: ASTM D 2467.
- 2.3 JOINING MATERIALS
- A. Solder Filler Metal: ASTM B 32, lead free.
- B. Brazing Filler Metals: AWS A5.8, alloys to suit system requirements.
- C. Solvent Cements: As recommended by manufacturer.
- D. Plastic Pipe Seals: ASTM F 477, elastomeric gasket.
- PART 3 - EXECUTION
- 3.1 VALVE APPLICATIONS
- A. Install gate valves close to main on each branch and riser serving two or more plumbing fixtures or equipment connections and where indicated.
- B. Install gate or ball valves on inlet to each plumbing equipment item, on each supply to each plumbing fixture not having stops on supplies, and elsewhere as indicated.
- C. Install drain valve at base of each riser, at low points of horizontal runs, and where required to drain water distribution piping system.
- D. Install swing check valve on discharge side of each pump and elsewhere as indicated.
- E. Install ball valves in each hot water circulating loop and discharge side of each pump.
- 3.2 PIPING INSTALLATIONS
- A. Install hangers and supports at intervals indicated in the applicable plumbing code and as recommended by pipe manufacturer.
- B. Support vertical piping at each floor.
- 3.3 INSPECTING AND CLEANING
- A. Inspect and test piping systems following procedures of authorities having jurisdiction.
- B. Clean and disinfect water distribution piping following procedures of authorities having jurisdiction.
- END OF SECTION 15140

SECTION 15150 - SANITARY WASTE AND VENT PIPING

- PART 1 - GENERAL
- 1.1 SECTION REQUIREMENTS
- A. Minimum Pressure Requirement for Soil, Waste and Vent: 10 foot head.
- B. Comply with NSF 14 "Plastic Piping Components and Related Materials".
- PART 2 - PRODUCTS
- 2.1 PIPES AND TUBES
- A. PVC Plastic, DWV Pipe: ASTM D 2665, Schedule 40, plain ends.
- 2.2 FITTINGS
- A. PVC Plastic, DWV Pipe Fittings: ASTM D 2665, made to ASTM D 3311; socket type; drain, waste, and vent pipe patterns.
- PART 3 - EXECUTION
- 3.1 PIPING INSTALLATION
- A. Install cleanout and extension to grade at connection of building sanitary drain and building sanitary sewer.
- B. Locate drainage piping runouts as close as possible to bottom of floor slab supporting fixtures or drains.
- 3.2 INSPECTION
- A. Inspect and test piping systems following procedures of authorities having jurisdiction.
- END OF SECTION 15150

SECTION 15198 - NATURAL GAS PIPING

- PART 1 - GENERAL
- 1.1 SECTION REQUIREMENTS
- A. Quality Assurance: Comply with NFPA 54 and the Plumbing Code.
- PART 2 - PRODUCTS
- 2.1 PIPE, TUBE, AND SPECIALTIES
- A. Steel Pipe: ASTM A 53, Type S (Seamless), Grade B, Schedule 40, plain ends.
- B. Malleable Iron Threaded Fittings: ASME B16.3, Class 150.
- C. Manual Valves: Comply with standards listed or, if appropriate, to ANSI Z21.15.
- D. Gas Stops: AGA certified, bronze-body, plug type with bronze plug, for 2-psig or less natural gas. Include AGA stamp, flat or square head or lever handle, and threaded ends complying with ASME B1.20.1.
- E. Gas Valves: 150-psig WOG, cast-iron or bronze body, bronze plug, straightaway pattern, square head, tapered-plug type.
- F. Gas Pressure Regulators: ANSI Z21.18, single stage, steel jacketed, corrosion resistant pressure regulators. Include atmospheric vent, elevation compensator. Regulator pressure ratings, inlet and outlet pressures, and flow volume in cubic feet per hour of natural gas at specific gravity are as indicated.
- G. Line Gas Pressure Regulators: Inlet pressure rating not less than system pressure.
- H. Flexible Connectors: ANSI Z21.24, copper alloy.
- I. Strainers: Bronze body, Y-pattern, full size of connecting piping. Include stainless-steel screens with 3/64 inch perforations and a pressure rating of 125-psig- minimum, WOG working pressure.
- PART 3 - EXECUTION
- 3.1 INSTALLATION
- A. Close equipment shutoff valves before turning off gas to premises or section of piping. Perform leakage test as specified to determine that all equipment is turned off in affected piping section.
- B. Install shutoff valve, downstream from gas meter, outside building at gas service entrance.
- C. Install gas stops for shutoff to appliances with NPS 2" or smaller low pressure gas supply.
- D. Drips and Sediment Traps: Install drips at points where condensate may collect. Include outlets of gas meters. Locate where readily accessible to permit cleaning and emptying. Do not install where condensate would be subject to freezing.
- E. Install gas piping at uniform slope of 0.1 percent upward toward risers.
- F. Connect branch piping from top or side of horizontal piping.
- G. Install strainers on supply side of each control valve, gas pressure regulator, solenoid valve, and elsewhere as indicated.
- H. Install valves in accessible locations, protected from damage.
- I. Install gas valve upstream from each gas pressure regulator. Where two gas-pressure regulators are installed in series, valve is not required at second regulator.
- J. Connect gas piping to equipment and appliances with shutoff valves and unions. Install gas valve upstream from and within 36 inches of each appliance using gas. Install union or flanged connection downstream from valve.
- K. Inspect, test, and purge piping according to NFPA 54, Part 4, "Gas Piping Inspection, Testing, and Purging", and requirements of authorities having jurisdiction.
- END OF SECTION 15198

SECTION 15410 - PLUMBING FIXTURES

- PART 1 - GENERAL
- 1.1 SECTION REQUIREMENTS
- Submittals: None.
- A. Comply with requirements of Public Law 102-486, "Energy Policy Act", regarding water flow rate and water consumption of plumbing fixtures.
- B. Comply with applicable standards below:
1. Enameled, Cast Iron Fixtures: ASME A112.19.1M.
2. National Sanitation Foundation Construction: NF52.
3. Porcelain Enameled Fixtures: ASME A112.19.4M.
4. Slip Resistant Bathing Surfaces: ASTM F 462.
5. Stainless Steel Fixtures: ASME A112.19.3M.
6. Vitreous China Fixtures: ASME A112.19.2M.
- PART 2 - PRODUCTS
- 2.1 Refer to the fixture schedule on drawing P600
- PART 3 - EXECUTION
- 3.1 INSTALLATION
- A. Install fixtures with flanges and gasket seals.
- B. Install flushometer valves for accessible water closets and urinals with handle mounted on wide side of compartment. Install other actuators in locations that are easy for the disabled to reach.
- C. Fasten wall hanging plumbing fixtures securely to supports attached to building substrate when supports are specified, and to building wall construction where no support is indicated.
- D. Fasten floor mounted fixtures to substrate. With fixtures having holes for securing fixture to wall construction, fasten to reinforcement built into walls.
- E. Fasten wall mounted fittings to reinforcement built into walls.
- F. Fasten counter mounted plumbing fixtures to casework.
- G. Secure supplies to supports or substrate within pipe space behind fixture.
- H. Set mop basins in leveling bed of cement grout.
- I. Install individual supply inlets, supply stops, supply risers, and tubular brass traps with cleanouts at fixture.
- J. Install water supply stop valves in accessible locations.
- K. Install traps on fixture outlets. Omit traps on fixtures having integral traps. Omit traps on indirect wastes, unless otherwise indicated or required by the Authority Having Jurisdiction.
- L. Install full-ring escutcheons at wall, floor, and ceiling penetrations in exposed, finished locations and within cabinets and millwork. Use deep pattern escutcheons where required to conceal protruding pipe fittings.
- M. Install piping connections between plumbing fixtures and piping systems and plumbing equipment. Install insulation on supplies and drains of fixtures for the disabled.
- N. Ground equipment. Tighten electrical connectors and terminals according to UL 486A and UL 486B.
- END OF SECTION 15410

SECTION 15554 - FLUES AND VENTS

- PART 1 - GENERAL
- 1.1 SECTION REQUIREMENTS
- A. Submittals: None.
- PART 2 - PRODUCTS
- 2.1 GAS VENTS
- A. Vent/air intake for high efficiency domestic water heater. Follow manufacturer's recommendations for sizing and material.
- B. Accessories: Tees, elbows, increasers, draft hood connectors, metal cap with bird barrier, adjustable roof flashing, storm collar, support assembly, thimbles, firestopping spacers, and fasteners; fabricated of similar materials and designs as vent-pipe straight sections.
- PART 3 - EXECUTION
- 3.1 INSTALLATION
- A. Install vents according to stipulated minimum clearances from combustibles.
- B. Seal between sections of positive pressure vents using only sealants recommended by manufacturer.
- C. Support vents at intervals to support the weight of the vent and all accessories, without exceeding loading of appliances.
- END OF SECTION 15554

PLUMBING ABBREVIATIONS

- (E) EXISTING
- ABV ABOVE
- ADA AMERICANS WITH DISABILITIES ACT
- AFF ABOVE FINISHED FLOOR
- AFG ABOVE FINISHED GRADE
- AHJ AUTHORITY HAVING JURISDICTION
- BFF BELOW FINISHED FLOOR
- BFG BELOW FINISHED GRADE
- BOH BACK OF HOUSE
- CLG CEILING
- CTE CONNECT TO EXISTING
- CW DOMESTIC COLD WATER
- DN DOWN
- EXTG EXISTING
- FCO FLOOR CLEANOUT
- FD FLOOR DRAIN
- FLR FLOOR
- FOH FRONT OF HOUSE
- FS FLOOR SINK
- FW DOMESTIC FILTERED COLD WATER
- GCO GRADE CLEANOUT
- GI GREASE INTERCEPTOR
- GT GREASE TRAP
- GW GREASE WASTE
- GYP GYPSUM BOARD
- HW DOMESTIC HOT WATER
- NTS NOT TO SCALE
- OIH OVERHEAD
- SAN SANITARY WASTE

PLUMBING ABBREVIATIONS

- ST STORM SEWER
- SW DOMESTIC SOFTENED COLD WATER
- TYP TYPICAL
- UG UNDERGROUND
- UNO UNLESS NOTED OTHERWISE
- WI WITH
- WIC WALK-IN COOLER
- C02AS TENANT'S C02 ALARM SUPPLIER
- GC GENERAL CONTRACTOR
- HES TENANT'S HVAC EQUIPMENT SUPPLIER
- HS TENANT'S HOOD SUPPLIER
- KES TENANT'S KITCHEN EQUIPMENT SUPPLIER
- LL LANDLORD
- SPS TENANT'S SODA POP SUPPLIER
- TAB TENANT'S TEST AND BALANCE VENDOR
- TCC TENANT'S CABLING CONTRACTOR
- TDC TENANT'S DUST CLEANER
- TEMS TENANT'S ENERGY MANAGEMENT SYSTEM SUPPLIER
- TLS TENANT'S LIGHT/LAMP SUPPLIER
- TMB TENANT'S MENU BOARD SUPPLIER
- TMS TENANT'S MILLWORK SUPPLIER
- TP TENANT'S PHONE SUPPLIER
- TRS TENANT'S RAILING SUPPLIER
- TSV TENANT'S SIGN VENDOR
- TUV TENANT'S UV SANITIZER SUPPLIER
- WCS TENANT'S WALK-IN COOLER SUPPLIER
- WHS TENANT'S WATER HEATER SUPPLIER

PLUMBING GENERAL NOTES


- A GENERAL NOTES APPLY TO PLUMBING SHEETS.
- B PLUMBING WORK SHALL BE DONE IN ACCORDANCE WITH THE PLUMBING CODE, LOCAL HEALTH DEPARTMENT STANDARDS, AND THE AUTHORITY HAVING JURISDICTION. SEE ARCHITECTURAL SHEETS FOR THE PREVAILING CODES.
- C PIPING LAYOUTS ON DRAWINGS ARE SCHEMATIC. EXACT LOCATIONS ARE TO BE COORDINATED WITH THE EXISTING CONDITIONS AND THE WORK OF OTHER TRADES.
- D CONCEAL PIPING UNLESS NOTED OTHERWISE. WATER SUPPLY PIPES SHALL BE INSTALLED LEVEL.
- E PROVIDE SHUT-OFF VALVES FOR ISOLATION OF FIXTURE GROUPS AS SHOWN ON DRAWINGS IN ADDITION TO STOP VALVES AT EACH FIXTURE.
- F PROVIDE STOP VALVES AT FIXTURES.
- G PROVIDE TRAP PRIMERS FOR FLOOR DRAINS AS SHOWN ON SHEET P100.
- H WHERE THE WATER SUPPLY LINE SIZE SHOWN IN THE PLUMBING DIAGRAMS DIFFERS FROM THE FIXTURE OR EQUIPMENT CONNECTION SIZE, PROVIDE LINE SIZE PIPE TO WITHIN 6" OF THE FIXTURE OR EQUIPMENT BEFORE TRANSITIONING TO THE CONNECTION SIZE.
- I PIPING IN EXTERIOR WALLS SHALL BE INSTALLED BETWEEN THE INSULATION AND THE INTERIOR WALL FINISHING MATERIAL.
- J INSULATE THE HOT AND COLD WATER, CONDENSATE DRAINAGE, AND STORM PIPING PER THE SPECIFICATIONS AND DETAIL 8P700.
- K NOT USED.
- L PLUMBING FIXTURES, ACCESSORIES, AND MATERIALS PROVIDED FOR DOMESTIC WATER SHALL BE LEAD FREE.
- M PRIOR TO TURNOVER PERFORM A VIDEO INSPECTION OF THE SANITARY AND GREASE LINES FROM THE MAIN LINES WITHIN THE TENANT SPACE TO THE MAIN SEWER TO VERIFY THAT THE SANITARY WASTE SYSTEM IS CONNECTED, CLEAN, AND FREE OF SAGS, BELLIES, BREAKS, AND DEBRIS. DELIVER A REPORT AND COPY OF THE VIDEO TO THE TENANT'S CONSTRUCTION MANAGER PRIOR TO TURNOVER.
- N THE TERM "FURNISH" MEANS SUPPLY AND DELIVER TO THE PROJECT SITE, READY FOR UNLOADING, UNPACKING, ASSEMBLY, INSTALLATION, AND SIMILAR OPERATIONS. THE TERM "INSTALL" DESCRIBES THE OPERATIONS AT THE PROJECT SITE INCLUDING THE ACTUAL UNLOADING, UNPACKING, ASSEMBLY, ERECTING, PLACING, ANCHORING, APPLYING, WORKING TO DIMENSION, FINISHING, CURING, PROTECTING, CLEANING, AND SIMILAR OPERATIONS. THE TERM "PROVIDE" MEANS TO FURNISH AND INSTALL, COMPLETE AND READY FOR THE INTENDED USE.
- O PRIOR TO CONNECTION TO ANY EXISTING SEWER SYSTEM PERFORM A DIE TEST TO VERIFY THE TYPE OF SYSTEM AND THE DIRECTION OF FLOW. REPORT ANY DEVIATION FROM THE CONSTRUCTION DOCUMENTS TO THE TENANTS' CONSTRUCTION MANAGER.
- P PROVIDE SANITARY AND GREASE WASTE PIPES AT A MINIMUM SLOPE OF 1/4" PER FOOT UNLESS NOTED OTHERWISE.
- Q EXISTING STORM DRAINAGE PROVIDED UNDER A SEPARATE CONSTRUCTION PACKAGE.

GENERAL SYMBOLS

- 1 PLAN KEYNOTE
- CONNECT TO EXISTING
- CONTINUATION SYMBOL
- ITEM TO BE DEMOLISHED
- AREA NOT IN CONTRACT
- PIPE SIZE TAG (DIAMETER)
- ABOVE GROUND PIPING
- BELOW GROUND PIPING
- EXISTING PIPE TAG
- PIPING BEING DEMOLISHED
- REDUCED PRESSURE ZONE BACKFLOW PREVENTER
- STRAINER
- TRAP PRIMER
- BALL VALVE
- BALANCING VALVE
- DOM. WATER METER
- PRESS REGULATOR
- CIRCUIT SETTER
- SWING CHECK
- CHECK VALVE
- SOLENOID VALVE
- BELOW GROUND
- FLOOR DRAIN
- FLOOR SINK
- FLOOR CLEANOUT (4")
- EQUIPMENT TAG
- GAS METER ASSEMBLY

PLUMBING AND PIPING SYMBOLS

- CONDENSATE DRAINAGE
- NATURAL GAS
- FIRE PROTECTION WET
- COMBINATION WASTE & VENT
- DOMESTIC COLD WATER
- HARD COLD WATER
- SOFT COLD WATER
- FILTERED COLD WATER
- HOT WATER
- HOT WATER RECIRCULATION
- GREASE WASTE
- INDIRECT WASTE
- SANITARY VENT
- SANITARY SEWER
- STORM DRAINAGE
- OVERFLOW STORM DRAINAGE

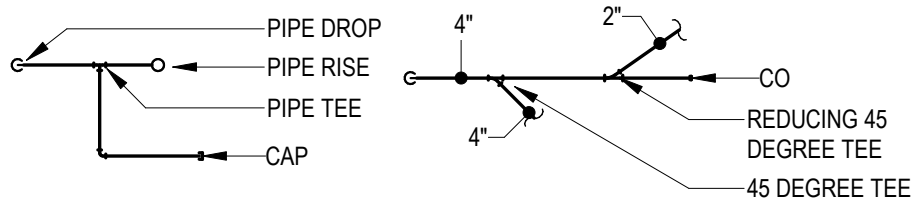

* NOTE *

ALL OF GENERAL NOTES ON THIS SHEET ARE TO BE APPLIED TO ALL OTHER DRAWINGS IN THIS SET. THE SYMBOLS AND ABBREVIATIONS SHOWN ON THIS SHEET MAY OR MAY NOT BE USED IN THIS SET OF DRAWINGS.

Consultant:

AYRES

MECHANICAL, ELECTRICAL,
PLUMBING (MEP)

1700 West Highway 36 - Suite 700
Roseville, Minnesota 55113
(651) 639-9606 Fax (651) 639-9618
Project No. 81-0606



COPYRIGHT 2024
THIS DRAWING IS AN INSTRUMENT OF SERVICE AND AS SUCH REMAINS THE PROPERTY OF CHIPOTLE MEXICAN GRILL, INC. PERMISSION FOR USE OF THIS DOCUMENT IS LIMITED AND CAN BE EXTENDED ONLY BY WRITTEN AGREEMENT WITH CHIPOTLE MEXICAN GRILL, INC.



CHIPOTLE MEXICAN GRILL, INC.
PO BOX 182566
COLUMBUS, OH 43218-2566
(614) 318-2400
www.chipotle.com

STORE NO.: 5037

"HUNTLEY"

12990 ROUTE 47, LOT 4B
HUNTLEY, IL 60142

Issue Record:	
01/30/2024	PERMIT SUBMITTAL
03/15/2024	BID SET
05/03/2024	CONSTRUCTION SET

Revisions:	

Drawn:	Checked:
RLD	LAO

Project No.

2023-0175

Contents:


PLUMBING
SPECIFICATIONS

P010


PLUMBING FIXTURE WASTE CONNECTIONS					
TAG	DESCRIPTION	CONNECTION SIZE - WASTE	DFU	COUNT	TOTAL DFU
DM-1	DISH SANITIZING MACHINE (PUMPED OUTLET)	5/8"	7	1	7
FCO-1	FLOOR CLEANOUT (3")	3"	0	2	0
FCO-2	FLOOR CLEANOUT (4")	4"	0	6	0
FD-1	FLOOR DRAIN	2"	2	6	12
FNL-1	FUNNEL DRAIN	2"	2	1	2
FS-1	FLOOR SINK	3"	5	8	40
HS-1A	RESTROOM HAND SINK	2"	1	2	2
HS-2	KITCHEN HAND SINK	2"	1	4	4
IM-1	ICE MAKER - BOH	1/2"	0	1	0
IM-2	ICE MAKER - SODA	1/2"	0	2	0
MB-1A	MOP BASIN	3"	2	1	2
SK-1	THREE COMPARTMENT SINK	2"	0	1	0
SK-2	PREP SINK	2"	0	1	0
TD-1	TRENCH DRAIN	2"	2	1	2
UR-1	URINAL - WALL HUNG	2"	4	1	4
WC-1	WATER CLOSET	3"	4	2	8
GRAND TOTAL					83

PLUMBING WASTE AND VENT PLAN NOTES

- 1 PROVIDE 3/4" CONDENSATE DRAIN FROM THE WALK-IN COOLER EVAPORATOR TO THE FLOOR SINK BELOW THE ICE MAKER AS SHOWN. SLOPE CONDENSATE DRAIN A MINIMUM OF 1" PER FOOT. HOLD EXPOSED CONDENSATE DRAIN IN WALK-IN COOLER AS HIGH AS POSSIBLE. CONCEAL DRAIN PIPING WITHIN FRAMED WALLS AS SHOWN. DISCHARGE THROUGH AN AIR GAP. MAKE FINAL CONNECTION TO EVAPORATOR INSIDE WALK-IN COOLER USING A UNION. CONDENSATE DRAIN SHOULD PENETRATE WALL BEHIND ICE MAKER AT 8" AFF AND BE SECURED TO FLOOR UNDER ICE MAKER.
- 2 PROVIDE DRAIN CONNECTIONS TO THE THREE COMPARTMENT SINK PER DETAIL 2/P700.
- 3 COORDINATE ROUTING OF SODA BUNDLES WITH COCA-COLA TECHNICIAN FROM BAG-IN-BOX AREA TO EACH SODA FOUNTAIN. OTHER THAN WITHIN THE WALLS DOWN TO THE DRYER BOX. THE SODA BUNDLE SHALL BE ROUTED OVERHEAD WITHOUT CONDUIT. COORDINATE SUPPORT AND ROUTING OF THE SODA LINE BUNDLES WITH COCA-COLA TECHNICIAN DURING ROUGH IN AND PROVIDE NECESSARY SUPPORTS. SEE ARCHITECTURAL DRAWINGS FOR SODA BUNDLE TERMINATION LOCATION AND PROVIDE TERMINATION PER DETAIL 12/P700. SODA BUNDLES SHALL NOT BE ROUTED EXPOSED IN THE DINING ROOM AREA.
- 4 NOT USED.
- 5 PROVIDE DRAIN LINES FROM THE FOOD PREP SINK TO THE FLOOR SINK. PROVIDE AN AIR GAP AT THE DISCHARGE TO THE FLOOR SINK.
- 6 PROVIDE VENT THROUGH THE ROOF PER DETAIL 3/P700.
- 7 GREASE INTERCEPTOR GI-1 AND 4" GREASE WASTE ARE STUBBED INTO BUILDING AND PROVIDED UNDER A SEPARATE CONSTRUCTION PACKAGE. REFER TO CIVIL PLANS FOR EXACT LOCATION, PIPE ROUTING, AND MANUFACTURER/MODEL NUMBER.
- 8 4" SANITARY SEWER IS STUBBED INTO BUILDING AND PROVIDED UNDER A SEPARATE CONSTRUCTION PACKAGE.
- 9 PROVIDE 3/4" VALVED DRAIN FROM HOT FOOD TABLE TO THE FLOOR SINK. DRAIN THROUGH AN AIR GAP.
- 10 PROVIDE INSULATED COPPER DRAIN LINES FROM THE TEA TRAY DRAIN AND THE SODA MACHINE DRAIN TO THE FLOOR SINK. DRAIN THROUGH AN AIR GAP. HOLD TEA TRAY DRAIN AS HIGH AS POSSIBLE AND SECURE TO STRUCTURE BELOW THE UTENSIL COUNTER.
- 11 TRIM TRENCH DRAIN ENDS PER THE MANUFACTURER'S INSTALLATION INSTRUCTIONS PRIOR TO INSTALLATION SO THAT GRATE FITS WITHOUT GAPS. INSTALL TRENCH DRAIN WITH SLIGHT POSITIVE SLOPE TOWARD THE DRAIN CONNECTION TO AVOID STANDING WATER IN TRENCH DRAIN.
- 12 2" VENT TO GREASE INTERCEPTOR GI-1 IS STUBBED INTO BUILDING AND PROVIDED UNDER A SEPARATE CONSTRUCTION PACKAGE.
- 13 DO NOT PROVIDE WALL CLEANOUTS ON TILE OR PUBLICLY-VISIBLE WALLS. IF A WALL CLEANOUT IS REQUIRED ON THESE SURFACE COORDINATE THE EXACT LOCATION WITH CHIPOTLE'S CONSTRUCTION MANAGER.
- 14 PROVIDE INDIRECT WASTE AND CONDENSATE DRAINS FROM FIXTURES CONCEALED IN THE WALL AS SHOWN IN DETAIL 9/P700.
- 15 PROVIDE DRAIN FROM WATER FILTER BFP TO MOP BASIN CONCEALED IN THE WALL AS SHOWN IN DETAIL 9/P700.
- 16 PROVIDE TRENCH DRAIN AS SHOWN IN DETAIL 15/P700.
- 17 INSTALL DRAIN HOSE FURNISHED WITH DISH MACHINE FROM DISH MACHINE OUTLET TO SANITARY SEWER FLOOR SINK. HOLD DRAIN HOSE TIGHT TO WALL. 3-COMP SINK DRAIN TO GREASE WASTE FLOOR SINK. MAINTAIN AN AIR GAP AT THE FLOOR SINK.
- 18 PROVIDE CONDENSATE TRAP ON RTU PER DETAIL 13/P700.
- 19 SEE DETAIL 16/P700 FOR DRAINS FROM TEA TRAY, ICE MAKER, AND SODA MACHINE TO FUNNEL DRAIN.
- 20 EXISTING STORM DRAINAGE PROVIDED BY LANDLORD.
- 21 NOT USED.
- 22 NOT USED.
- 23 PROVIDE PVC DRAIN PIPES FROM THE ICE MACHINE TO THE FLOOR SINK PER THE MANUFACTURER'S INSTALLATION INSTRUCTIONS. PROVIDE A CODE-APPROVED AIR GAP AT THE DISCHARGE TO THE FLOOR SINK. SECURE ICE MAKER DRAIN PIPES TO THE BOTTOM OF THE ICE MAKER.
- 24 PROVIDE DRAIN LINE FROM WATER SOFTENER TO NEARBY FLOOR SINK WITH AIR GAP AT DISCHARGE.

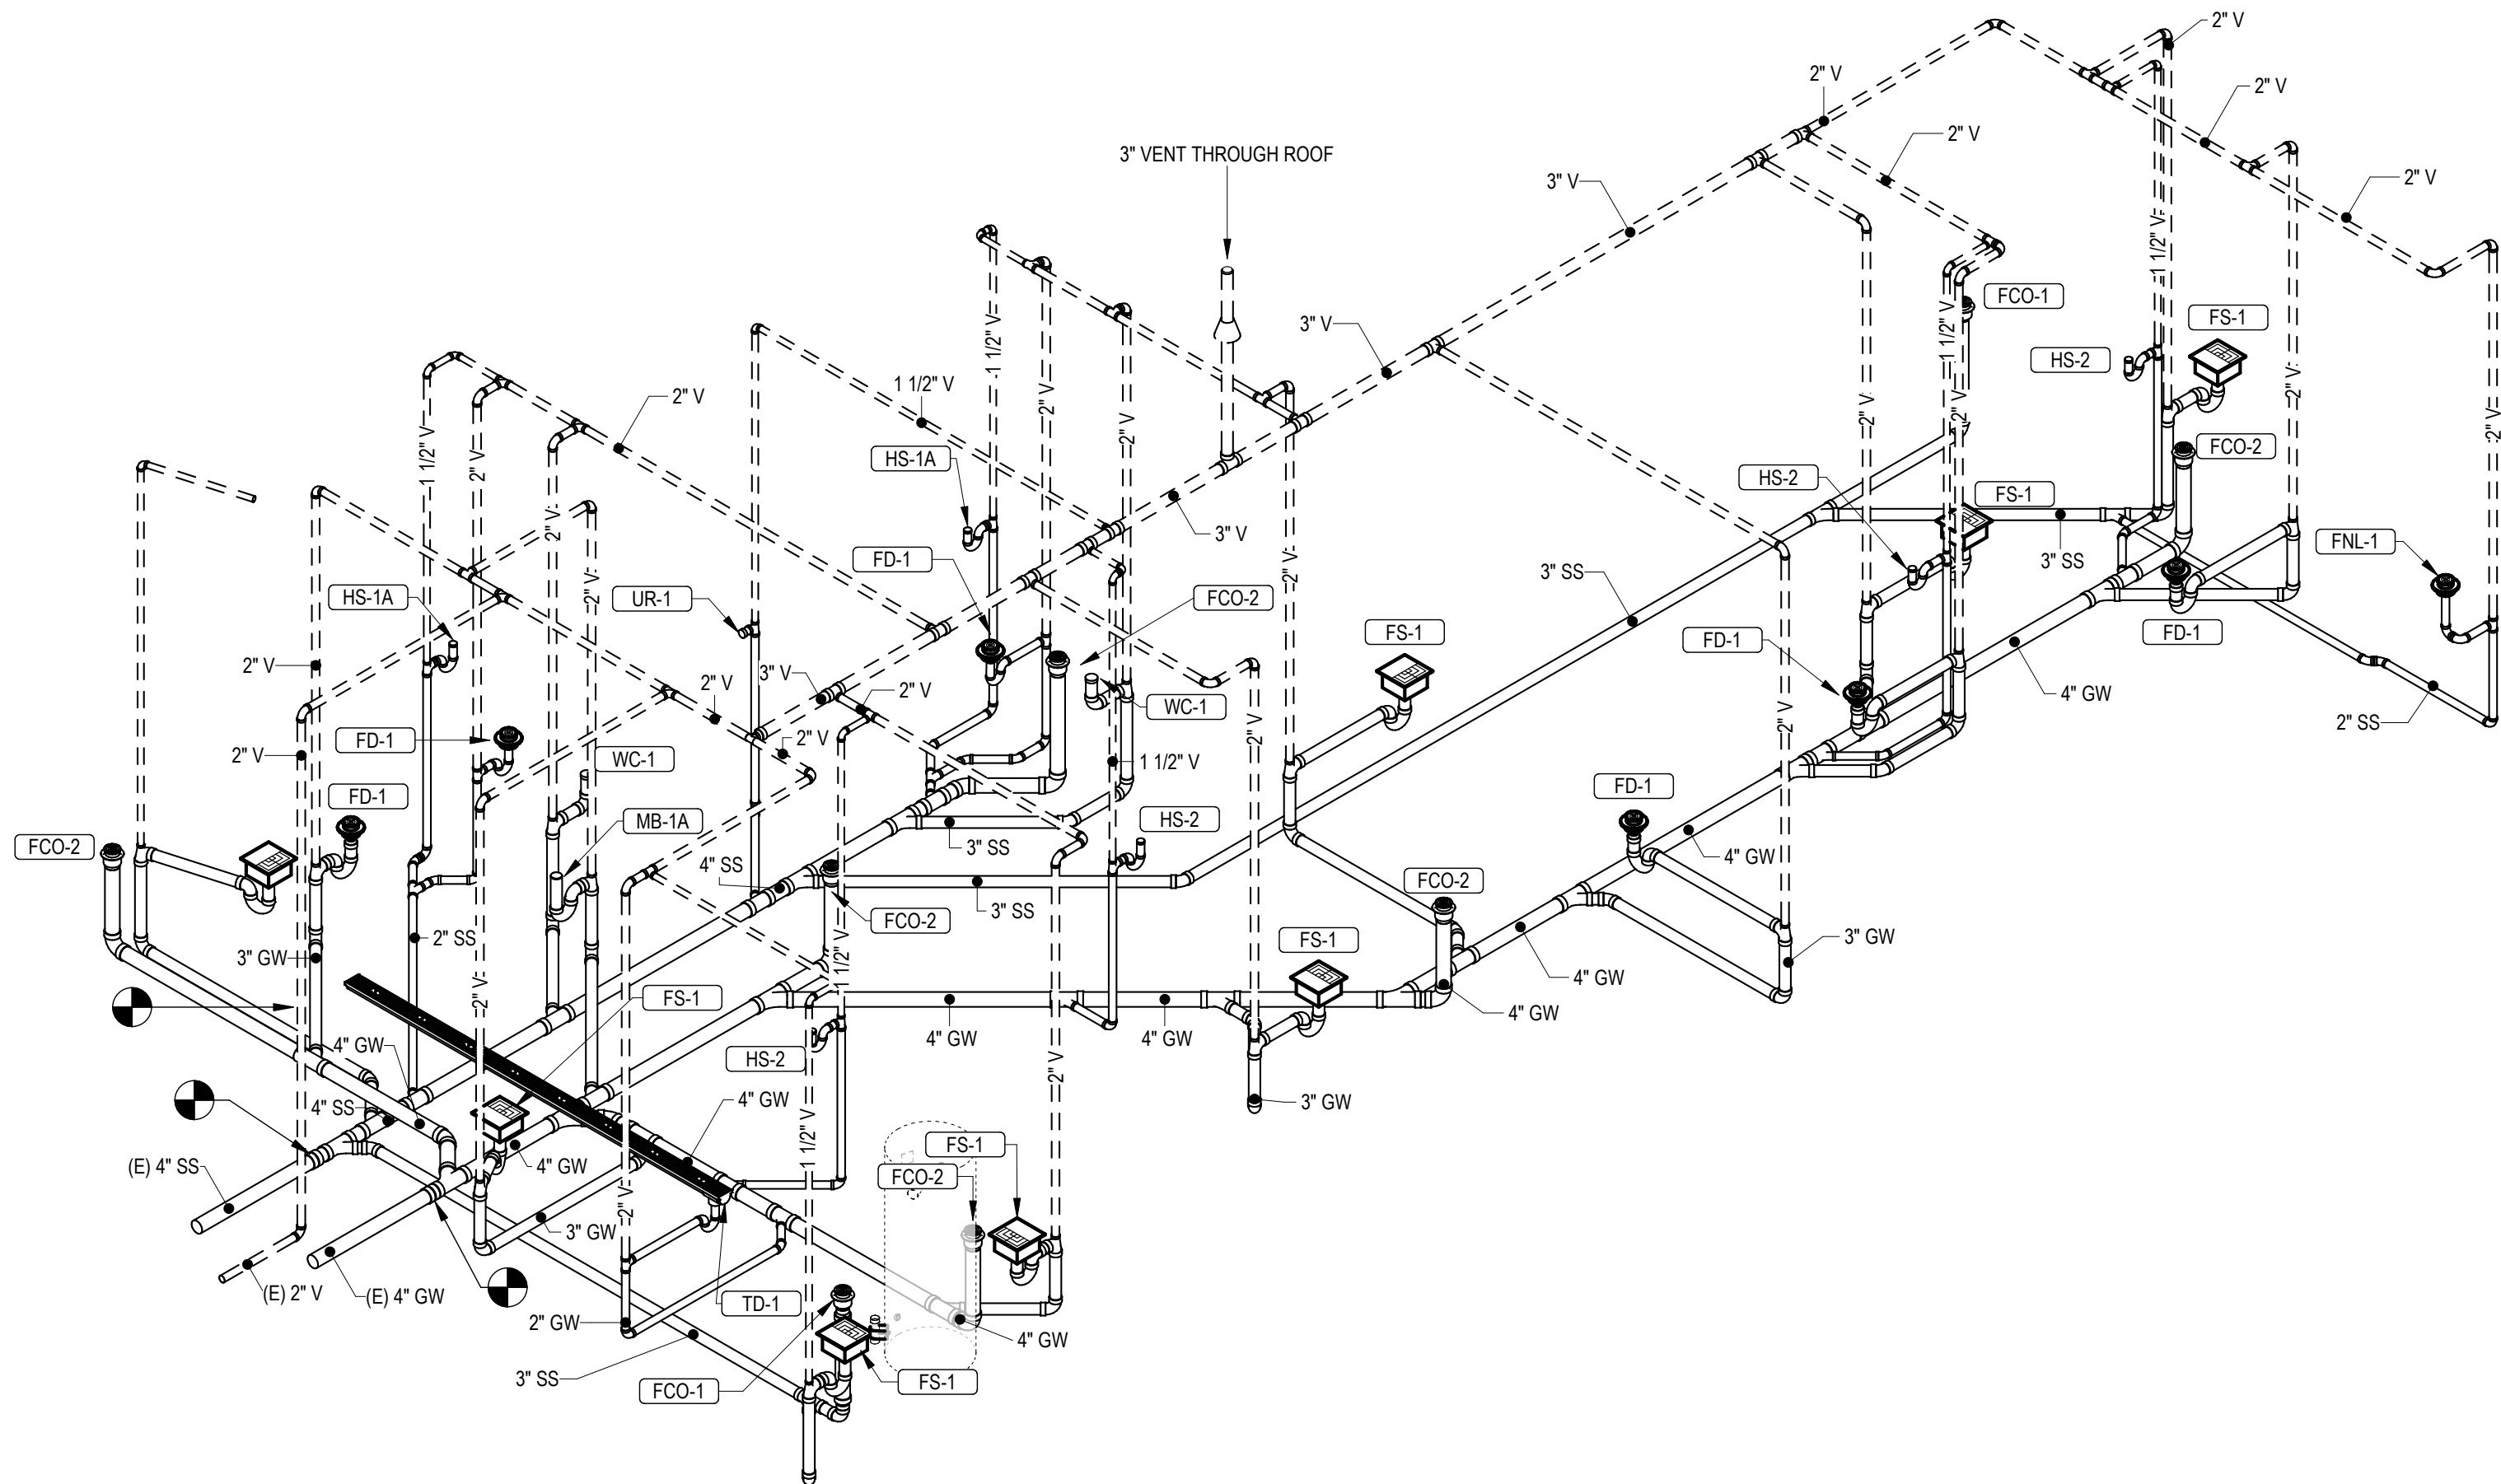

2 SANITARY WASTE & VENT RISER DIAGRAM
P110 NOT TO SCALE

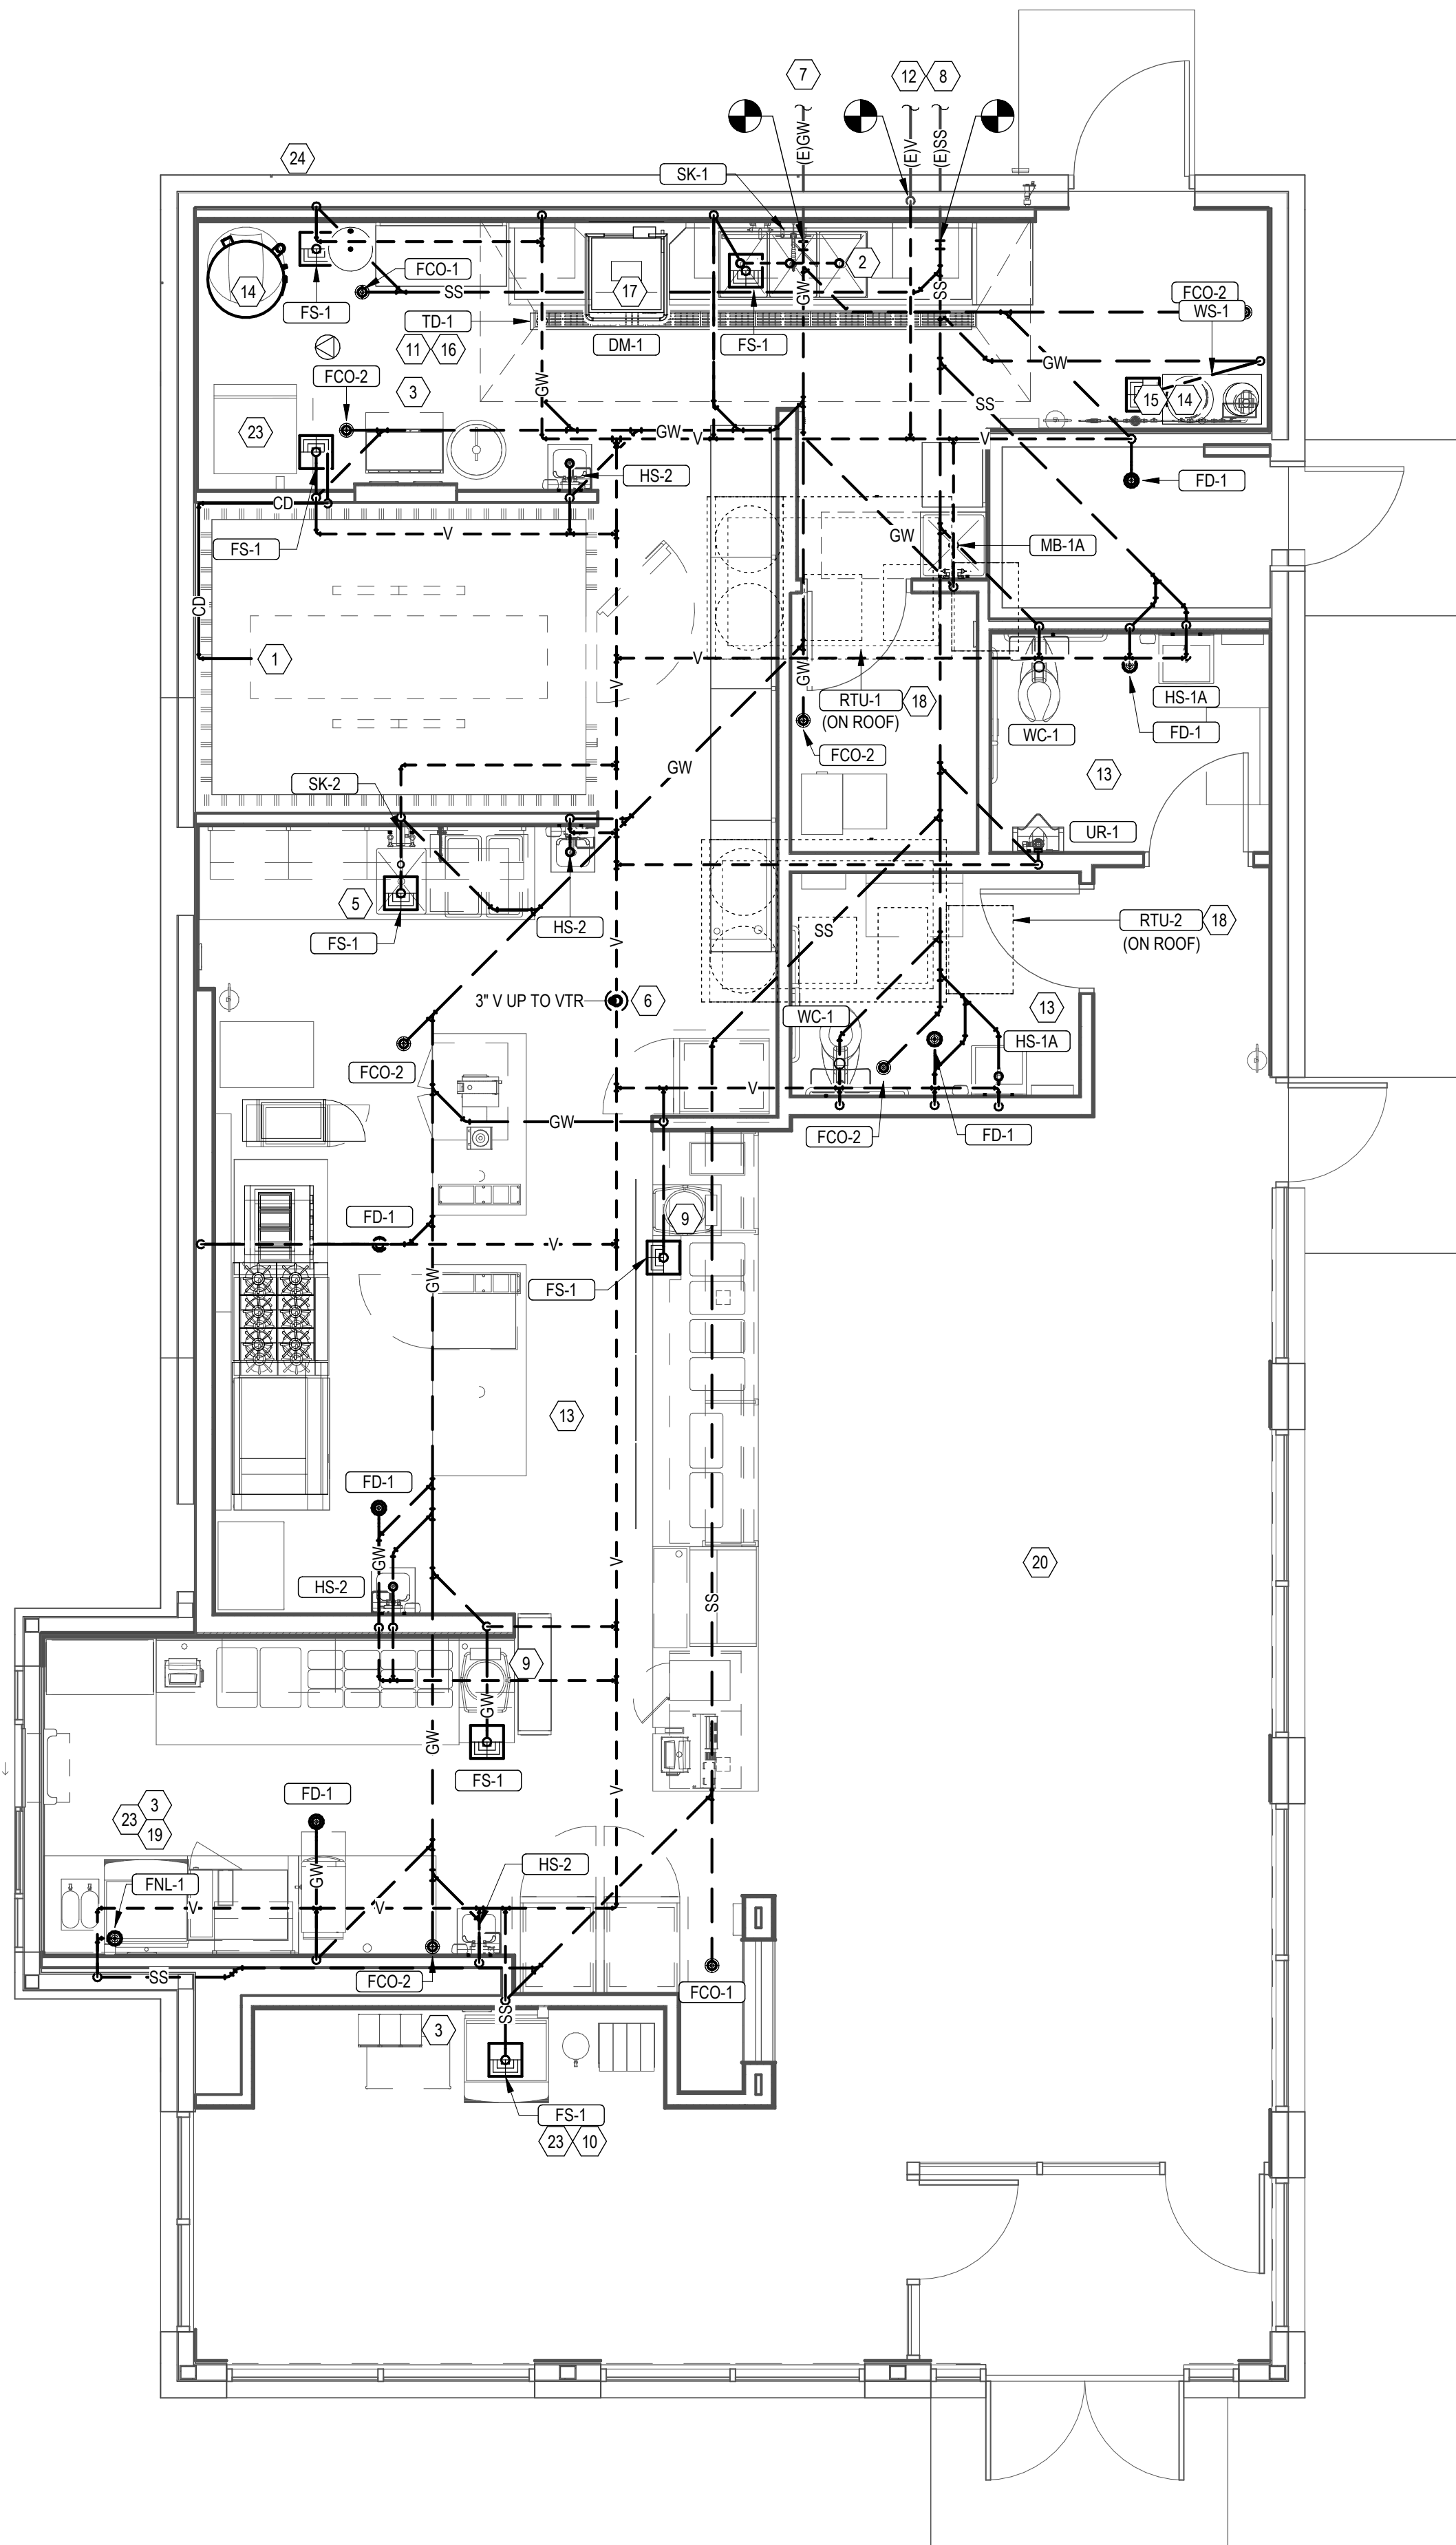

1 SANITARY WASTE & VENT PLAN
P110 1/4" = 1'-0"

Consultant:

AYRES
MECHANICAL, ELECTRICAL,
PLUMBING (MEP)
1700 West Highway 36 - Suite 700
Roseville, Minnesota 55113
(651) 639-9606 Fax (651) 639-9618
Project No. 81-0606



COPYRIGHT 2024
THIS DRAWING IS AN INSTRUMENT OF SERVICE AND AS SUCH REMAINS THE PROPERTY OF CHIPOTLE MEXICAN GRILL, INC. PERMISSION FOR USE OF THIS DOCUMENT IS LIMITED AND CAN BE EXTENDED ONLY BY WRITTEN AGREEMENT WITH CHIPOTLE MEXICAN GRILL, INC.



STORE NO.: 5037
"HUNTLEY"
12990 ROUTE 47, LOT 4B
HUNTLEY, IL 60142

Issue Record:	
01/30/2024	PERMIT SUBMITTAL
03/15/2024	BID SET
05/03/2024	CONSTRUCTION SET

Revisions:	
03/07/24	CITY COMMENTS

Drawn:	Checked:
RLD	LAO

Project No.
2023-0175

Contents:

PLUMBING PLAN
WASTE & VENT

P110

Consultant:



COPYRIGHT 2024
THIS DRAWING IS AN INSTRUMENT OF SERVICE AND
AS SUCH REMAINS THE PROPERTY OF CHIPOTLE
MEXICAN GRILL, INC. PERMISSION FOR USE OF THIS
DOCUMENT IS LIMITED AND CAN BE EXTENDED ONLY
BY WRITTEN AGREEMENT WITH CHIPOTLE MEXICAN
GRILL, INC.



STORE NO.: 5037
"HUNTLEY"
12990 ROUTE 47, LOT
HUNTLEY, IL 60142

Issue Record:	
01/30/2024	PERMIT SUBMITTAL
03/15/2024	BID SET
05/03/2024	CONSTRUCTION SET

Revisions:

03/07/24	CITY COMMENTS

Drawn:	Checked:
RLD	LAO

Project No. _____

2023-0175

Contents:


PLUMBING SCHEDULES

P600


PLUMBING FIXTURE SCHEDULE														
TAG	DESCRIPTION	FURNISHED BY	INSTALLED BY	BASIS FOR DESIGN		REMARKS	QTY	CONNECTION SIZE			WATER SUPPLY FIXTURE UNITS			DRAINAGE FIXTURE UNITS
				MANUFACTURER	MODEL			CW	HW	WASTE	CW	HW	TOTAL	
BFP-1	RPZ BACKFLOW PREVENTER	GC	GC	CONBRACO	4ALF-203-12F	LEAD FREE REDUCED PRESSURE PRINCIPLE BACKFLOW PREVENTER WITH AUTOMATIC DIFFERENTIAL RELIEF VALVE	1	1/2"			0	0		
BFP-2	RPZ BACKFLOW PREVENTER	EXTG	EXTG	-	-	LEAD FREE REDUCED PRESSURE PRINCIPLE BACKFLOW PREVENTER WITH AUTOMATIC DIFFERENTIAL RELIEF VALVE AND AIR GAP FITTING	1	1 1/2"			0	0	0	
DM-1	DISH SANITIZING MACHINE (PUMPED OUTLET)	KES	GC	SEE ARCH	-	CHEMICAL SANITIZING DISH MACHINE WITH INTEGRAL ELECTRIC BOOSTER HEATER AND PUMPED OUTLET	1		3/4"	5/8"	0	3	3	7
ET-1	EXPANSION TANK	GC	GC	AMTROL	T-12	4.4 GALLON CAPACITY	1	3/4"						
FB-1	GAS FRYER	KES	GC	SEE ARCH	-		1							
FCO-1	FLOOR CLEANOUT (3")	GC	GC	SIOUX CHIEF	852-3PNR	ON-GRADE ADJUSTABLE CLEANOUT WITH INTEGRAL THREADED CLEANOUT PLUG AND ROUND NICKEL-BRONZE RING AND COVER (OR APPROVED EQUAL WITH INTERNAL THREADED CLEANOUT PLUG)	1			3"				0
FCO-2	FLOOR CLEANOUT (4")	GC	GC	SIOUX CHIEF	852-4PNR	ON-GRADE ADJUSTABLE CLEANOUT WITH INTEGRAL THREADED CLEANOUT PLUG AND ROUND NICKEL-BRONZE RING AND COVER (OR APPROVED EQUAL WITH INTERNAL THREADED CLEANOUT PLUG)	1			4"				0
FD-1	FLOOR DRAIN	GC	GC	SIOUX CHIEF	842-2-PNR	ADJUSTABLE FLOOR DRAIN WITH PVC BODY, ROUND POLISHED METAL RING AND STRAINER, AND TRAP PRIMER PORT	6	1/2"		2"				2
FNL-1	FUNNEL DRAIN	GC	GC	JAY R. SMITH	3823T	FUNNEL DRAIN WITH CAST BRONZE BODY AND THREADED OUTLET	1			2"				2
FS-1	FLOOR SINK	GC	GC	SIOUX CHIEF	861-3PU2	HEAVY DUTY PVC FLOOR SINK WITH ALUMINUM DOME BOTTOM STRAINER AND OPEN HALF PVC GRATE	8			3"				5
GR-1	GAS GRIDDLE	KES	GC	SEE ARCH	-		1							
HB-1	CHEMICAL DISPENSER HOSE BIB	KES	GC	SEE ARCH	-	COMMERCIAL QUALITY HOT & COLD MIXING WALL HYDRANT. SUPPLY ARMS SHALL HAVE INTEGRAL SHUT-OFF STOP AND CHECK VALVE. FAUCET HAS FEMALE NPT INLETS.	2	1/2	1/2		2.25	2.25	3	
HB-2	VEGETABLE WASH HOSE BIB	KES	GC	SEE ARCH	-	SILL FAUCET WITH NPT FEMALE INLET	1	1/2"			1.5	0	1.5	
HS-1A	RESTROOM HAND SINK	GC	GC	KOHLER	K-2084	ADA-ACCESSIBLE, WALL-MOUNTED, PORCELAIN LAVATORY. PROVIDE ZURN Z1231 (Z1231-0 FOR BACK-TO-WALL APPLICATIONS) CONCEALED ARM CARRIER IN WALL	2			2"	0	0	0	1
HS-1B	RESTROOM HAND SINK FAUCET	KES	GC	SEE ARCH	-	PLUG-IN AUTOMATIC FAUCET WITH 0.5 GPM AERATOR AND THERMOSTATIC MIXING VALVE. ADJUST FAUCET CONTROLS FOR 10 SECOND SHUTOFF DELAY AND 30 SECOND TIME-OUT DELAY.	2	1/2"	1/2"		1.5	1.5	2	0
HS-2	KITCHEN HAND SINK	KES	GC	SEE ARCH	-	STAINLESS STEEL SINK WITH WALL MOUNTING BRACKET AND BACKSPASH MOUNTED FAUCET WITH SWIVEL GOOSENECK	4	1/2"	1/2"	2"	1.5	1.5	2	1
IM-1	ICE MAKER - BOH	KES	KES	SEE ARCH	-	BACK OF HOUSE ICE MAKER WITH BIN	1	1/2"			1	0	1	0
IM-2	ICE MAKER - SODA	KES	KES	SEE ARCH	-	SODA MACHINE-MOUNTED ICE MACHINE	2	1/2"			1	0	1	0
MB-1A	MOP BASIN	GC	GC	FIAT	MSB3424	PROVIDE 24"x24"x10" MOLDED-STONE MOP BASIN. INSTALL MOP BASIN IN A BED OF GROUT SO THERE ARE NO VOIDS BETWEEN THE MOP BASIN AND THE SLAB.	1			3"	0	0	0	2
MB-1B	MOP SINK FAUCET	KES	GC	SEE ARCH	-	SERVICE SINK FAUCET WITH BUILT IN STOPS, LEVER HANDLES, WALL BRACE, AND NPT FEMALE INLETS	1	1/2"	1/2"		2.25	2.25	3	0
PF-1	SPEED FILL FAUCET	KES	GC	SEE ARCH	-	WALL-MOUNTED POT FILLER W/ SELF-CLOSING FILLER VALVE AND NPT FEMALE INLET	1	3/8"			1.5	0	1.5	
RC-1	RICE COOKER	KES	GC	SEE ARCH	-		1							
RH-1	FREEZE PROOF ROOF HYDRANT	GC	GC	HOEPTNER	2131R	AUTOMATIC DRAINING, FREEZELESS ROOF HYDRANT WITH ANTI-SIPHON VACUUM BREAKER HOEPTNER PRODUCTS (408) 847-7615	1	3/4"			1	0	1	0
RN-1	6-BURNER RANGE	KES	GC	SEE ARCH	-		1							
SC-1	BAG-IN-BOX SODA RACK WITH CARBONATORS	SPS	SPS	SEE ARCH	-	SODA CARBONATOR(S) SHALL HAVE AN INTEGRAL ASSE 1022-RATED CARBONATED BEVERAGE BACKFLOW PREVENTION DEVICE.	1	1/2"			1	0	1	
SK-1	THREE COMPARTMENT SINK	KES	GC	SEE ARCH	-	THREE-COMPARTMENT WARE-WASHING SINK FURNISHED WITH (1) PRE-RINSE UNIT WITH ADD-ON FAUCET	1	1/2"	1/2"	2"	3	3	4	0
SK-2	PREP SINK	KES	GC	SEE ARCH	-	STAINLESS STEEL PREP TABLE WITH INTEGRAL PREP SINK. FURNISHED WITH "BIG FLO" FAUCET	1	3/4"	3/4"	2"	3	3	4	0
TD-1	TRENCH DRAIN	GC	GC	ZURN	Z886 8601 8602	6" X 160" HDPE TRENCH DRAIN (SLOPED FROM 3.50' TO 4.70') WITH (2) CLOSED END CAPS, (1) 4" NO-HUB BOTTOM OUTLET, AND CLASS-A HEEL-PROOF POLYETHYLENE GRATES. SEE DETAIL ON SHEET P700 FOR REDUCTION TO 2" DRAIN CONNECTION.	1			2"	0	0	0	2
TP-3	TRAP PRIMER	GC	GC	PRECISION PLUMBING PRODUCTS	P1-500 W/ DU-4	TRAP PRIMER WITH INTEGRAL VACUUM BREAKER AND DISTRIBUTION UNIT. CAP UNUSED DISTRIBUTION UNIT OUTLETS.	2	1/2"			0			
UR-1	URINAL - WALL HUNG	GC	GC	KOHLER	BARDON	WALL HUNG URINAL WITH WASHOUT ACTION, TOP SPUD, WITH INTEGRAL EXTENDED SHIELDS SUPPORTED BY THROUGH GOING BOLTS AND C.P. NUTS, AND MANUFACTURERS MANUAL ACTIVATED FLUSHOMETER.	1	3/4"	2"		5	0	5	4
WC-1	WATER CLOSET	GC	GC	KOHLER	K-3519 W/ SEAT K-4666-C	WHITE HIGHLIGHT 1.0 GPF, 17-1/8" HIGH, ADA ACCESSIBLE. PRESSURE ASSIST WATER CLOSET WITH OPEN-FRONT SEAT. INSTALL TRIP LEVER ON THE TANK TO THE OPEN SIDE OF THE STALL (ADD -RA TO THE MODEL #FOR RIGHT HAND TRIP LEVER).	2	1/2"	3"		2	0	2	4
WH-1	FREEZE PROOF WALL HYDRANT	EXTG	EXTG	WOODFORD	MODEL 65	AUTOMATIC DRAINING, FREEZELESS WALL HYDRANT WITH ANTI-SIPHON VACUUM BREAKER. PROVIDE WITH STEM LONG ENOUGH TO REACH INSIDE THE THERMAL ENVELOPE OF THE BUILDING.	2	3/4"			1	0	1	0
WS-1	WATER SOFTENER	KES	GC	CUNO	CFSM1254E	WATER TREATMENT SYSTEM SOFTENER WITH SALT MONITOR AND SAFETY BRINE VALVE. MAXIMUM CAPACITY 65,000 GRAINS. OPERATES ON 24V/60HZ,TRANSFORMER INCLUDED.	1	1"						

WATER HEATER SCHEDULE														
ID	DESCRIPTION	FURNISHED BY	INSTALLED BY	MANUFACTURER	MODEL NO.	TYPE	GAS-FIRED HEAT EXCHANGER					THERMAL EFF	UNIT WEIGHT	REMARKS
							GAS BURNER	WATERSIDE			MAX TEMP RISE			
								FUEL TYPE	STORAGE					
									RECOVERY	VOL				
DWH-1	TANK-TYPE WATER HEATER	WHS	GC	AO SMITH	BTH-199	CONDENSING	199000 Btu/h	NG	336 gal/h	100.0 gal	70 °F	97%	1350 lb	STATE SUP-100-199NE IS AN APPROVED EQUAL.

DOMESTIC CIRCULATING PUMP SCHEDULE														
ID	SYSTEM	MANUFACTURER	MODEL NO.	TYPE	PUMP		MOTOR		UNIT WEIGHT	OPTIONS		VOLT	PH	REMARKS
					DESIGN FLOW	HEAD	POWER	ECM		AQUASTAT	TIMER KIT			
P-1	DOM. HW-R	BELL & GOSSETT	EOCIRC 19-16	INLINE	2.0 GPM	5.0 FT	60 W	Yes	7 lb	Yes	Yes	120 V	1	DOMESTIC HOT WATER CARTRIDGE-TYPE CIRCULATOR WITH INTEGRAL TIMER PROVIDED WITH AQUASTAT SET AT APPROXIMATELY 100 DEGREES FAHRENHEIT, TO BE FURNISHED AND INSTALLED BY GC.

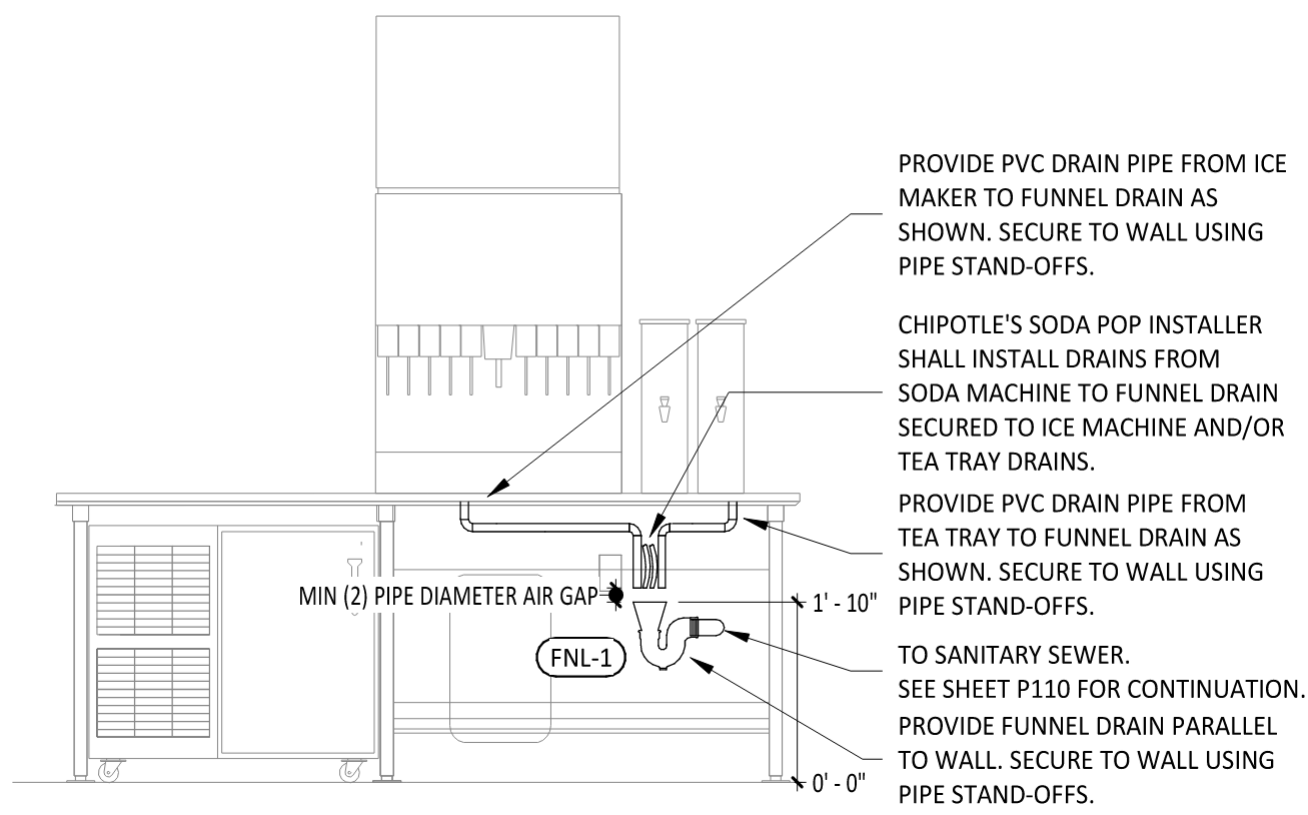


19 PUW FUNNEL DRAIN DETAIL
NOT TO SCALE

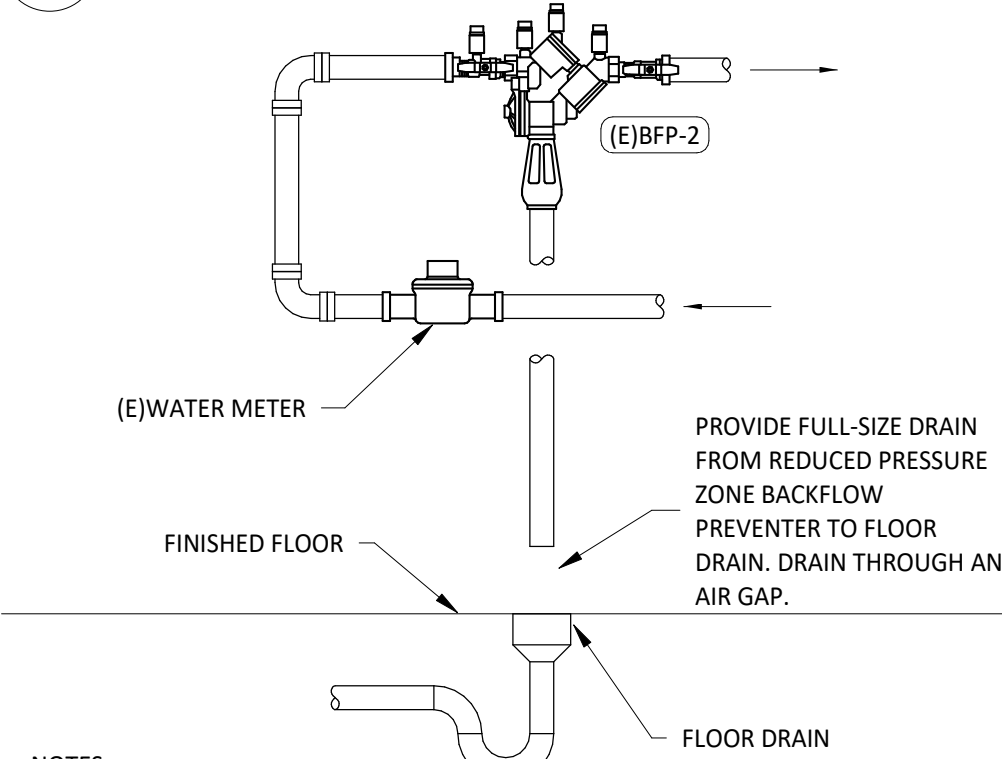


NOTES:
MAKE NECESSARY ARRANGEMENTS WITH WATER COMPANY TO INSTALL NEW WATER SERVICE PER LOCAL CODES & WATER COMPANY REGULATIONS AND PAY ALL CHARGES. SERVICE SHALL BE SIZED PER THE PLUMBING PLAN & INSTALLED IN STRICT ACCORDANCE OF WATER COMPANY REGULATIONS. ANCHOR METER, BACKFLOW PREVENTER, AND PIPING TO THE WALL OR THE FLOOR. CERTIFY THE BACKFLOW PREVENTER PER THE WATER COMPANY'S REQUIREMENTS.

16 EXISTING WATER SERVICE ENTRY DETAIL
NOT TO SCALE

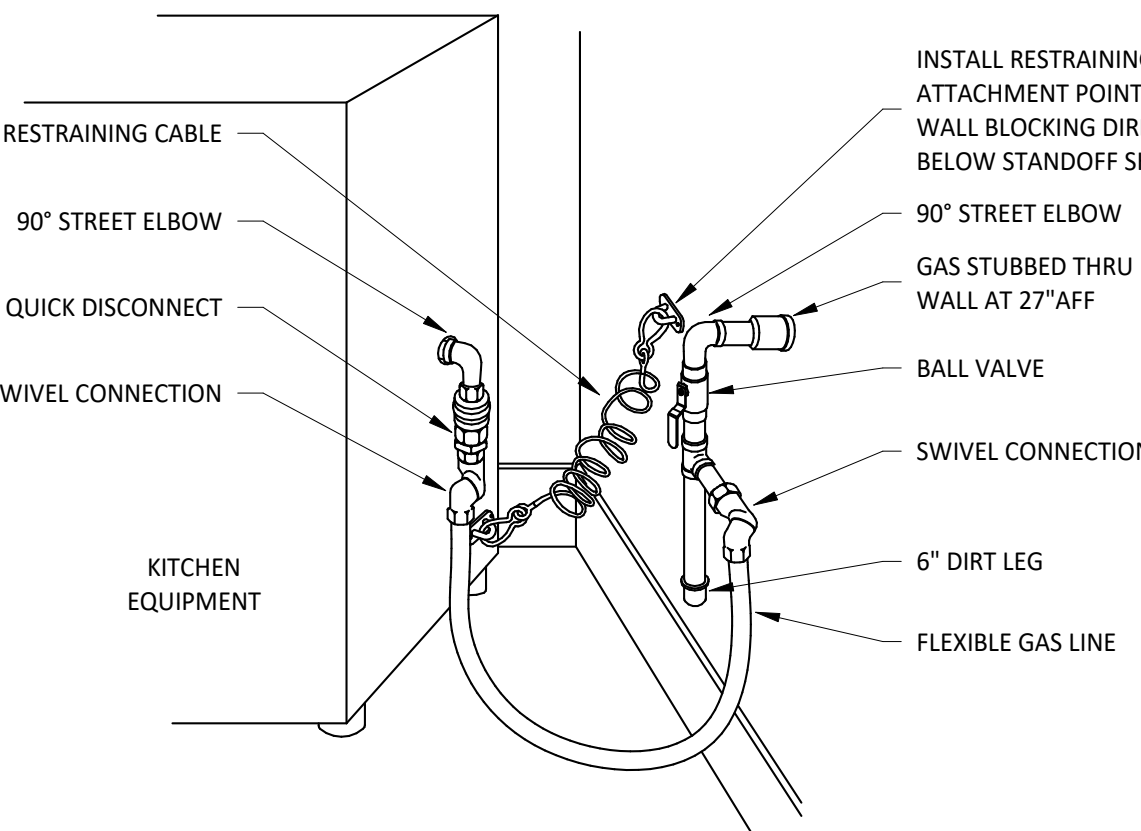

ARRANGEMENT SHOWN IS SCHEMATIC. ADJUST TO SUIT ACTUAL CONDITIONS. MAKE FINAL CONNECTION TO EQUIPMENT AS RECOMMENDED BY MANUFACTURER. PROVIDE WELDED FITTINGS/JOINTS IN ANY CONCEALED, UNSLEEVED LOCATION.


7 KITCHEN GAS EQUIPMENT DETAIL
NOT TO SCALE

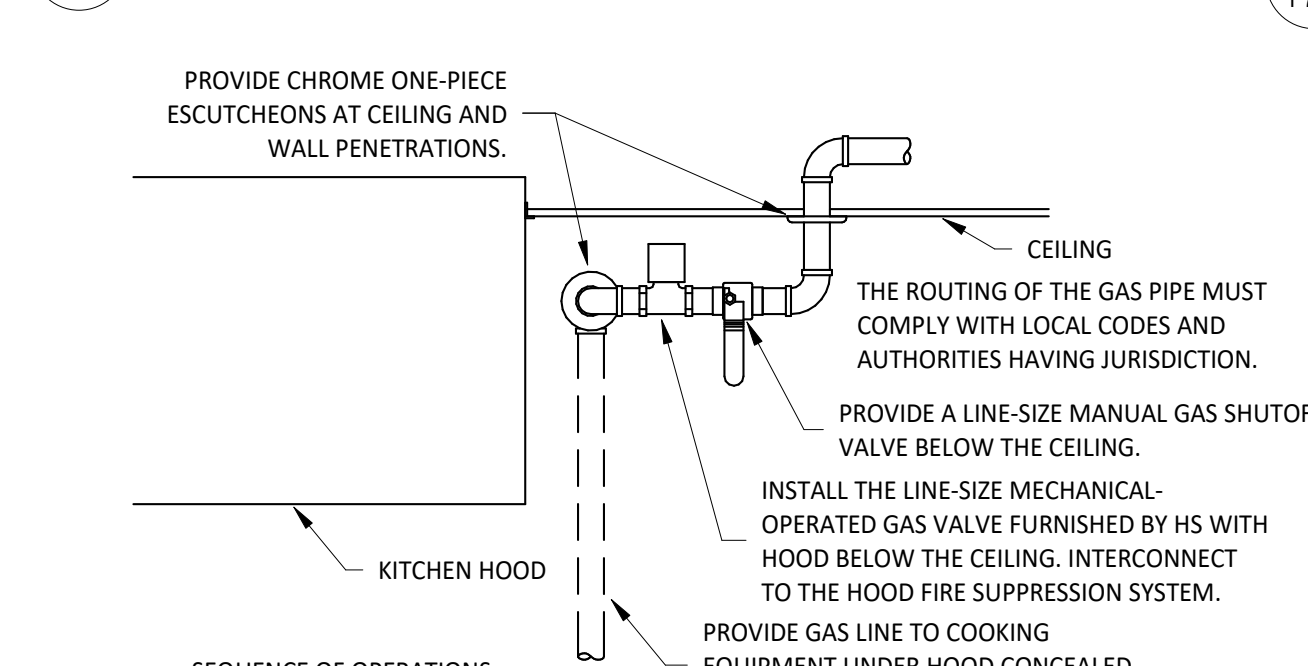


4 KITCHEN GAS SHUTOFF DETAIL
NOT TO SCALE

SEQUENCE OF OPERATIONS:
NORMAL MODE:
• DURING NORMAL OPERATION THE GAS SHUT-OFF VALVE SHALL BE OPEN.
EMERGENCY MODE:
• UPON ACTUATION OF THE HOOD FIRE SUPPRESSION SYSTEM THE GAS SHUT-OFF VALVE SHALL CLOSE.


4 KITCHEN GAS SHUTOFF DETAIL
NOT TO SCALE

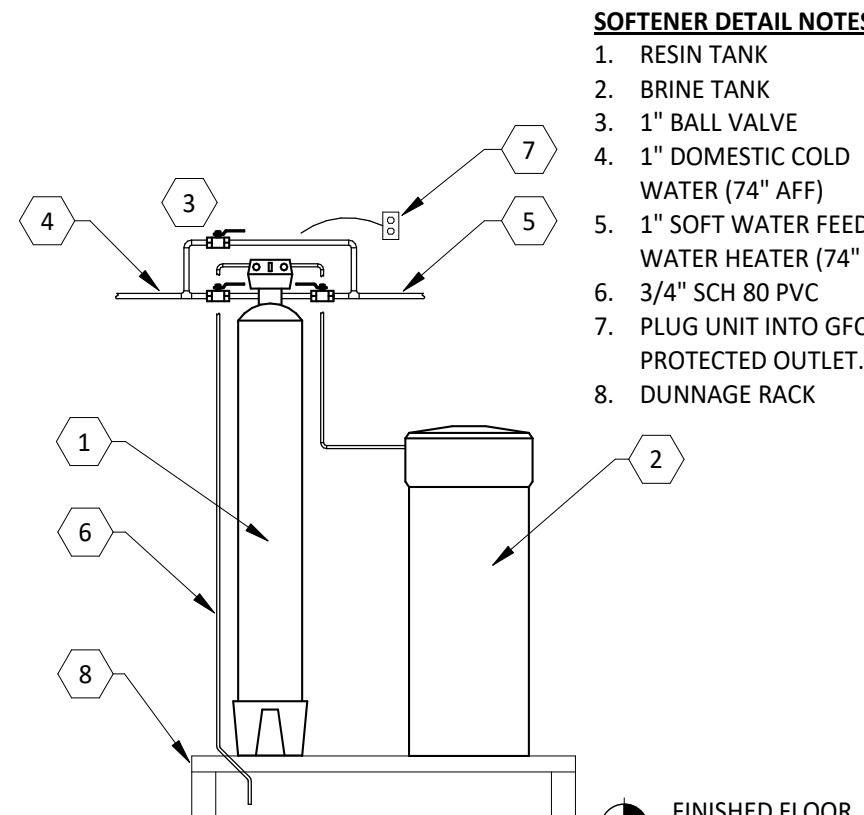


18 WATER SOFTENER DETAIL
NOT TO SCALE

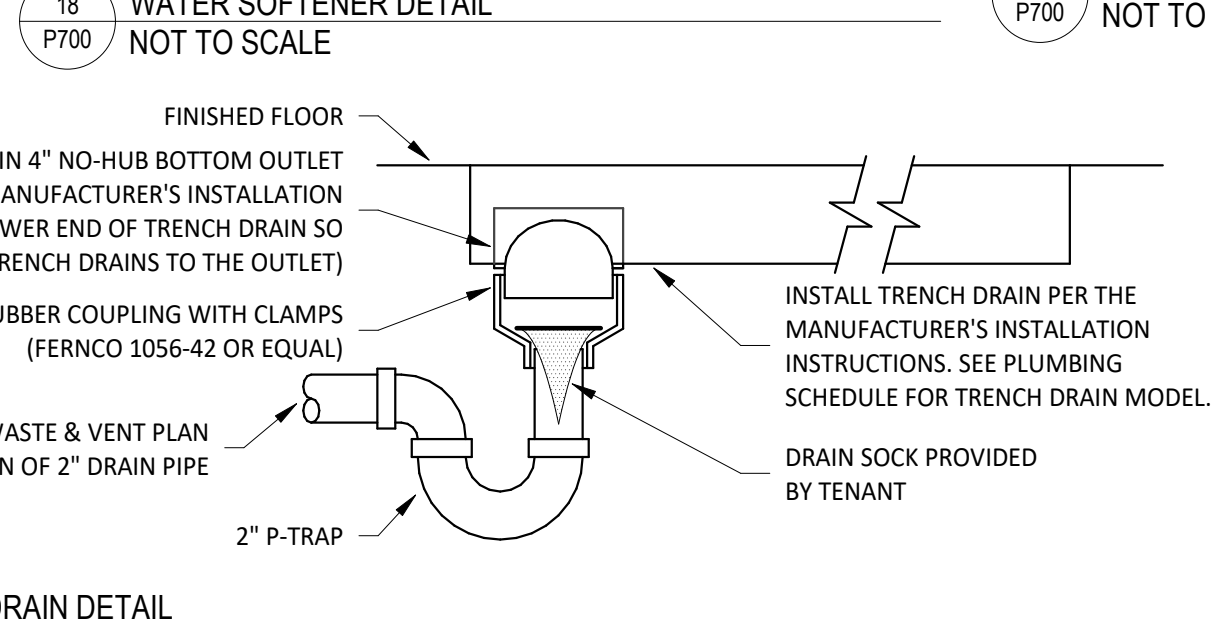

15 TRENCH DRAIN DETAIL
NOT TO SCALE

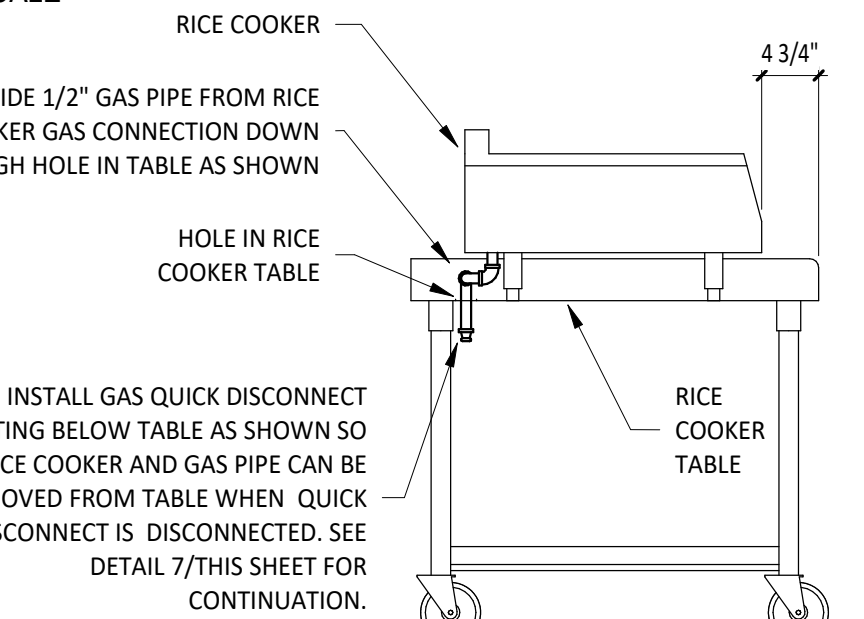


6 RICE COOKER GAS CONNECTION DETAIL
NOT TO SCALE

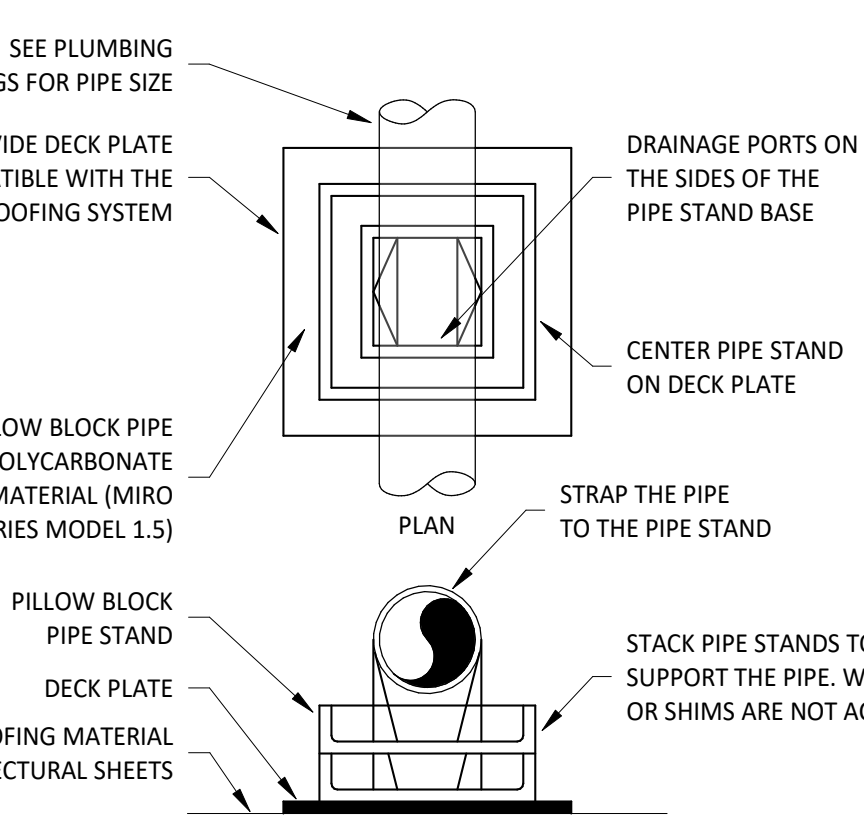


PROVIDE PIPE STANDS AS SHOWN FOR STEEL PIPE FROM 1/2" TO 1-1/2" DIAMETER. SUPPORT SPACING FOR PIPE SIZE: 1/2"-6"; 3/4"-1"-8"; 1 1/4" AND LARGER-10'. PROVIDE DECK PLATES ON ROOFING AND SET PIPE STAND FREE ON DECK PLATES. STACK PIPE STAND WHERE REQUIRED TO ELEVATE PIPING. INSTALL GAS PIPE TO ALLOW FOR EXPANSION AND CONTRACTION.

5 ROOFTOP PIPING SUPPORT
NOT TO SCALE

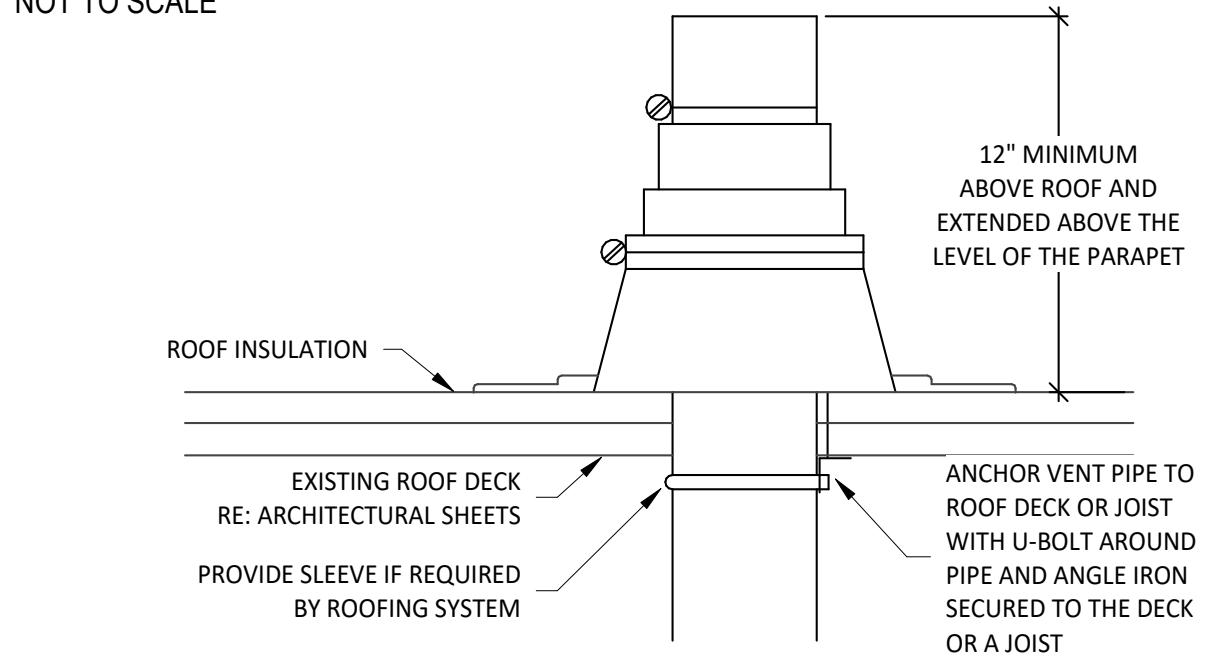


REFER TO PLANS FOR VTR PIPE SIZES AND LOCATIONS. LOCATE VTR MINIMUM TEN FEET HORIZONTAL OR THREE FEET VERTICAL ABOVE ANY BUILDING OPENING OR FRESH AIR INTAKE, AND ONE FOOT FROM ANY VERTICAL SURFACE. PROVIDE 1" FIBERGLASS INSULATION WITH ALL-SERVICE JACKET ON VENT PIPE INSIDE BUILDING WITHIN SIX FEET OF VENT THRU ROOF LOCATION. FLASHING AND COUNTER FLASHING ARE TO BE COMPATIBLE WITH THE ROOFING SYSTEM.


3 VENT THROUGH ROOF
NOT TO SCALE

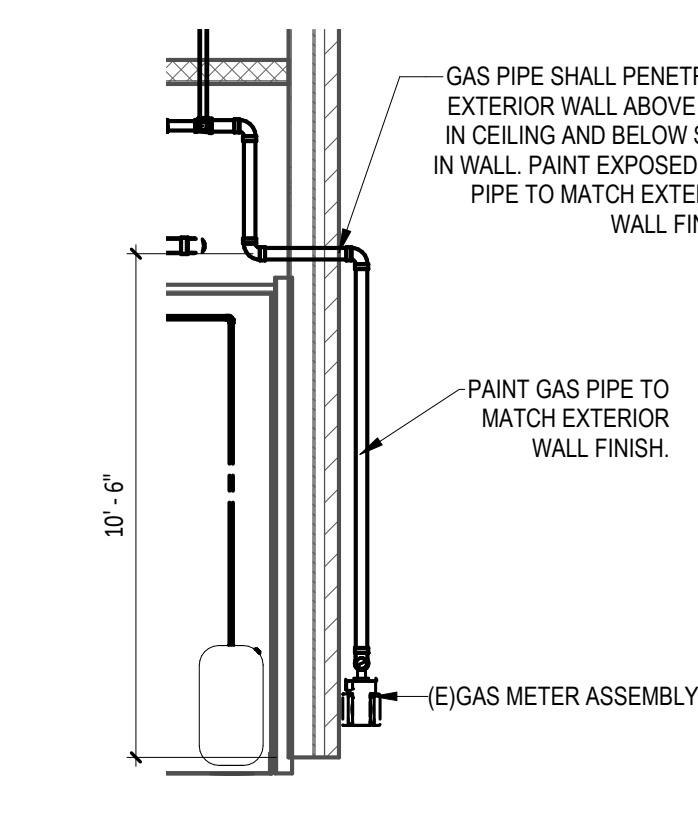


17 GAS METER SECTION
NOT TO SCALE

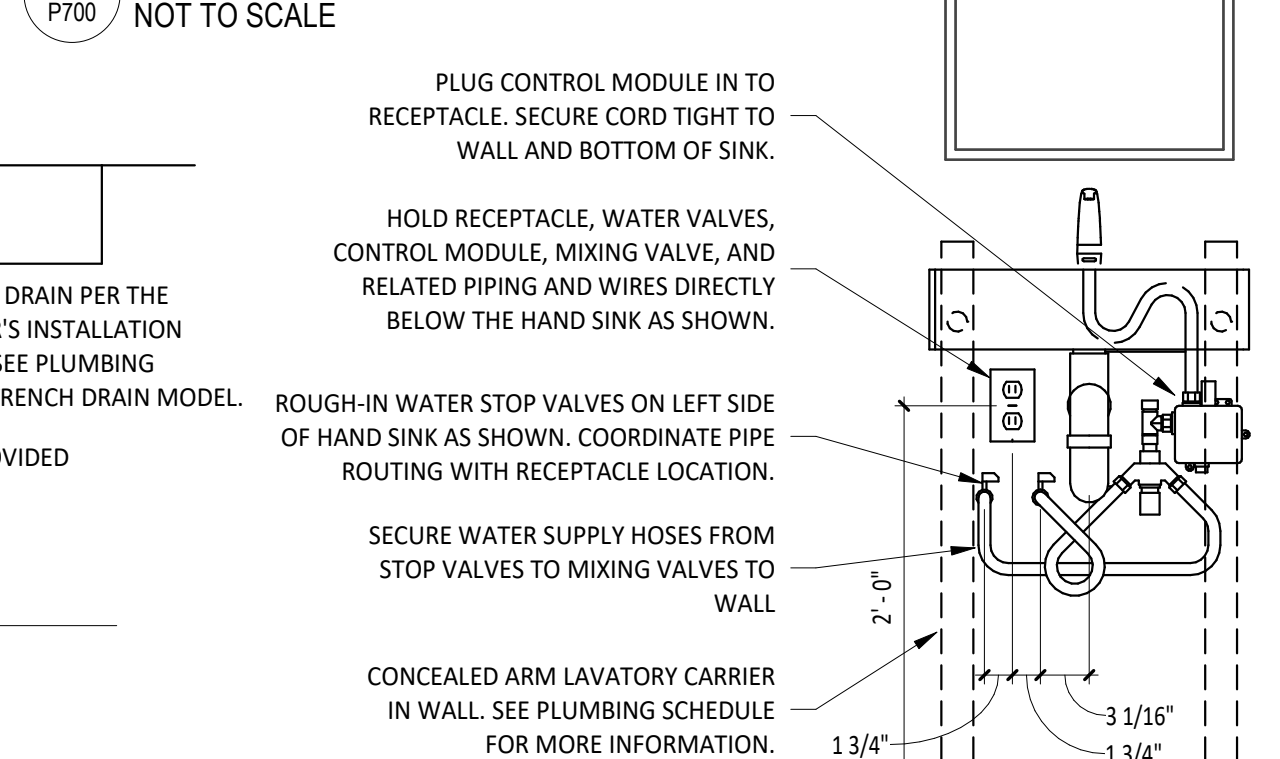

14 RESTROOM HAND SINK DETAIL
NOT TO SCALE

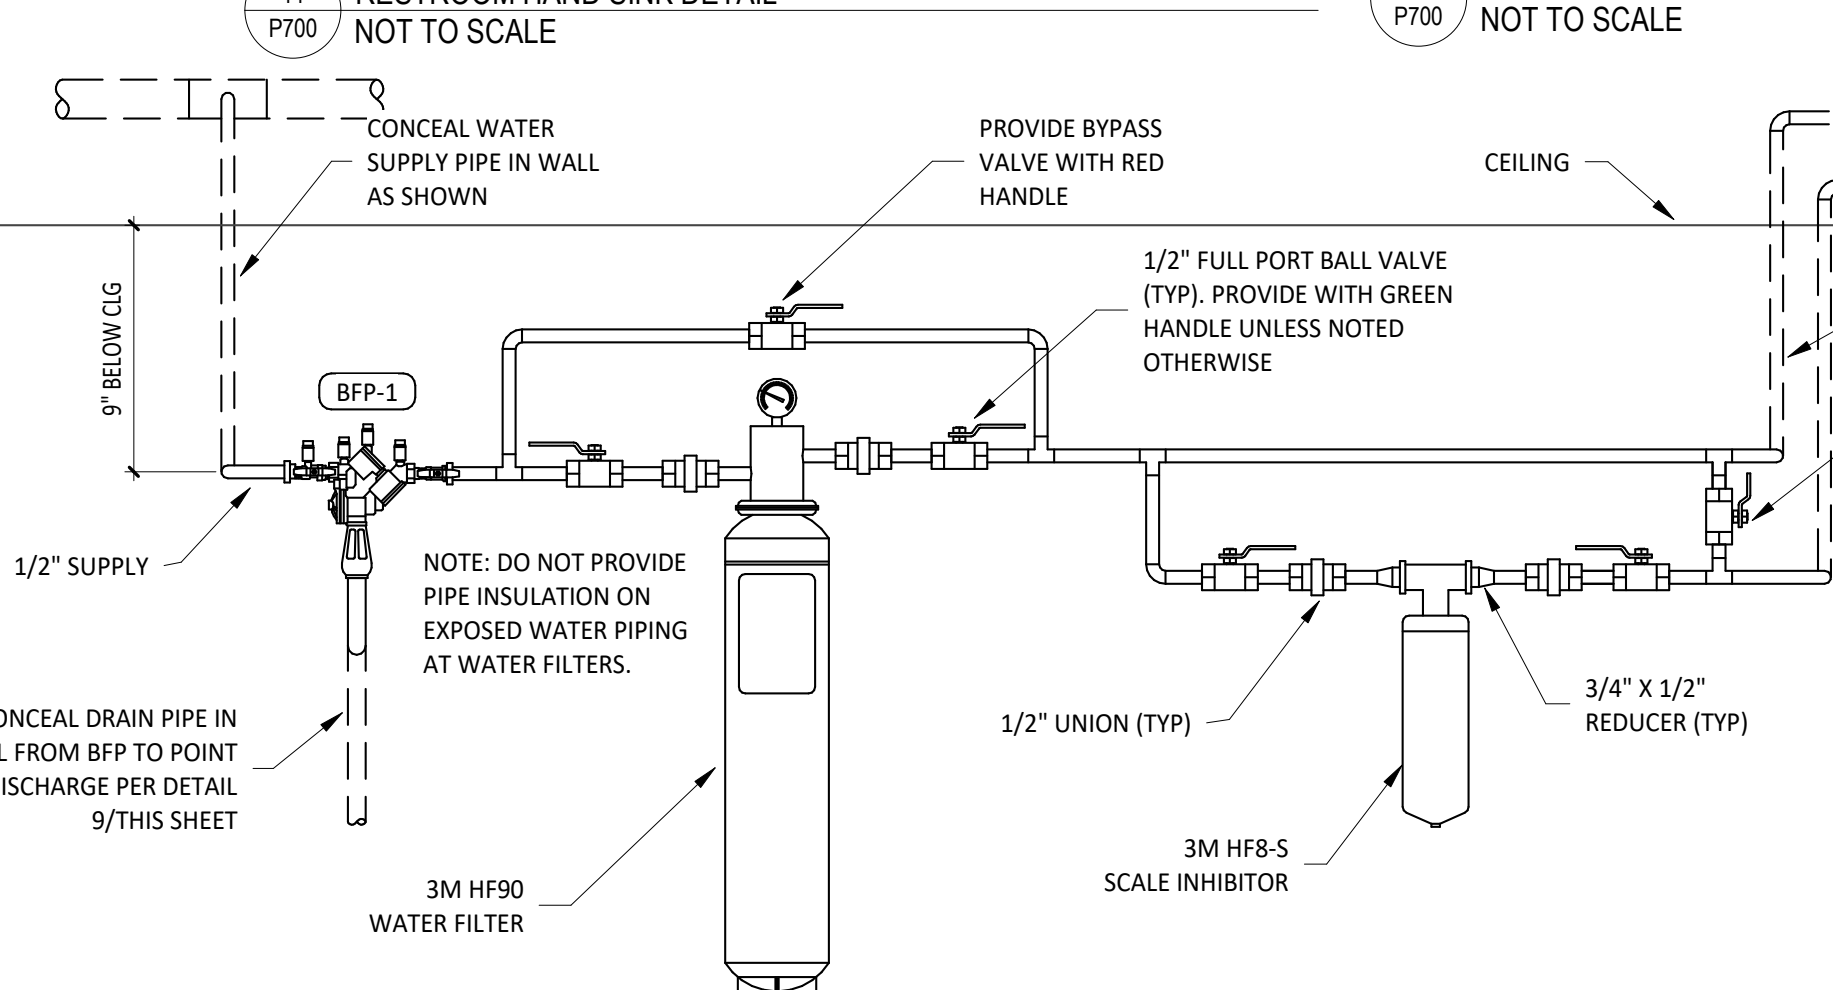


11 WATER FILTRATION DETAIL
NOT TO SCALE

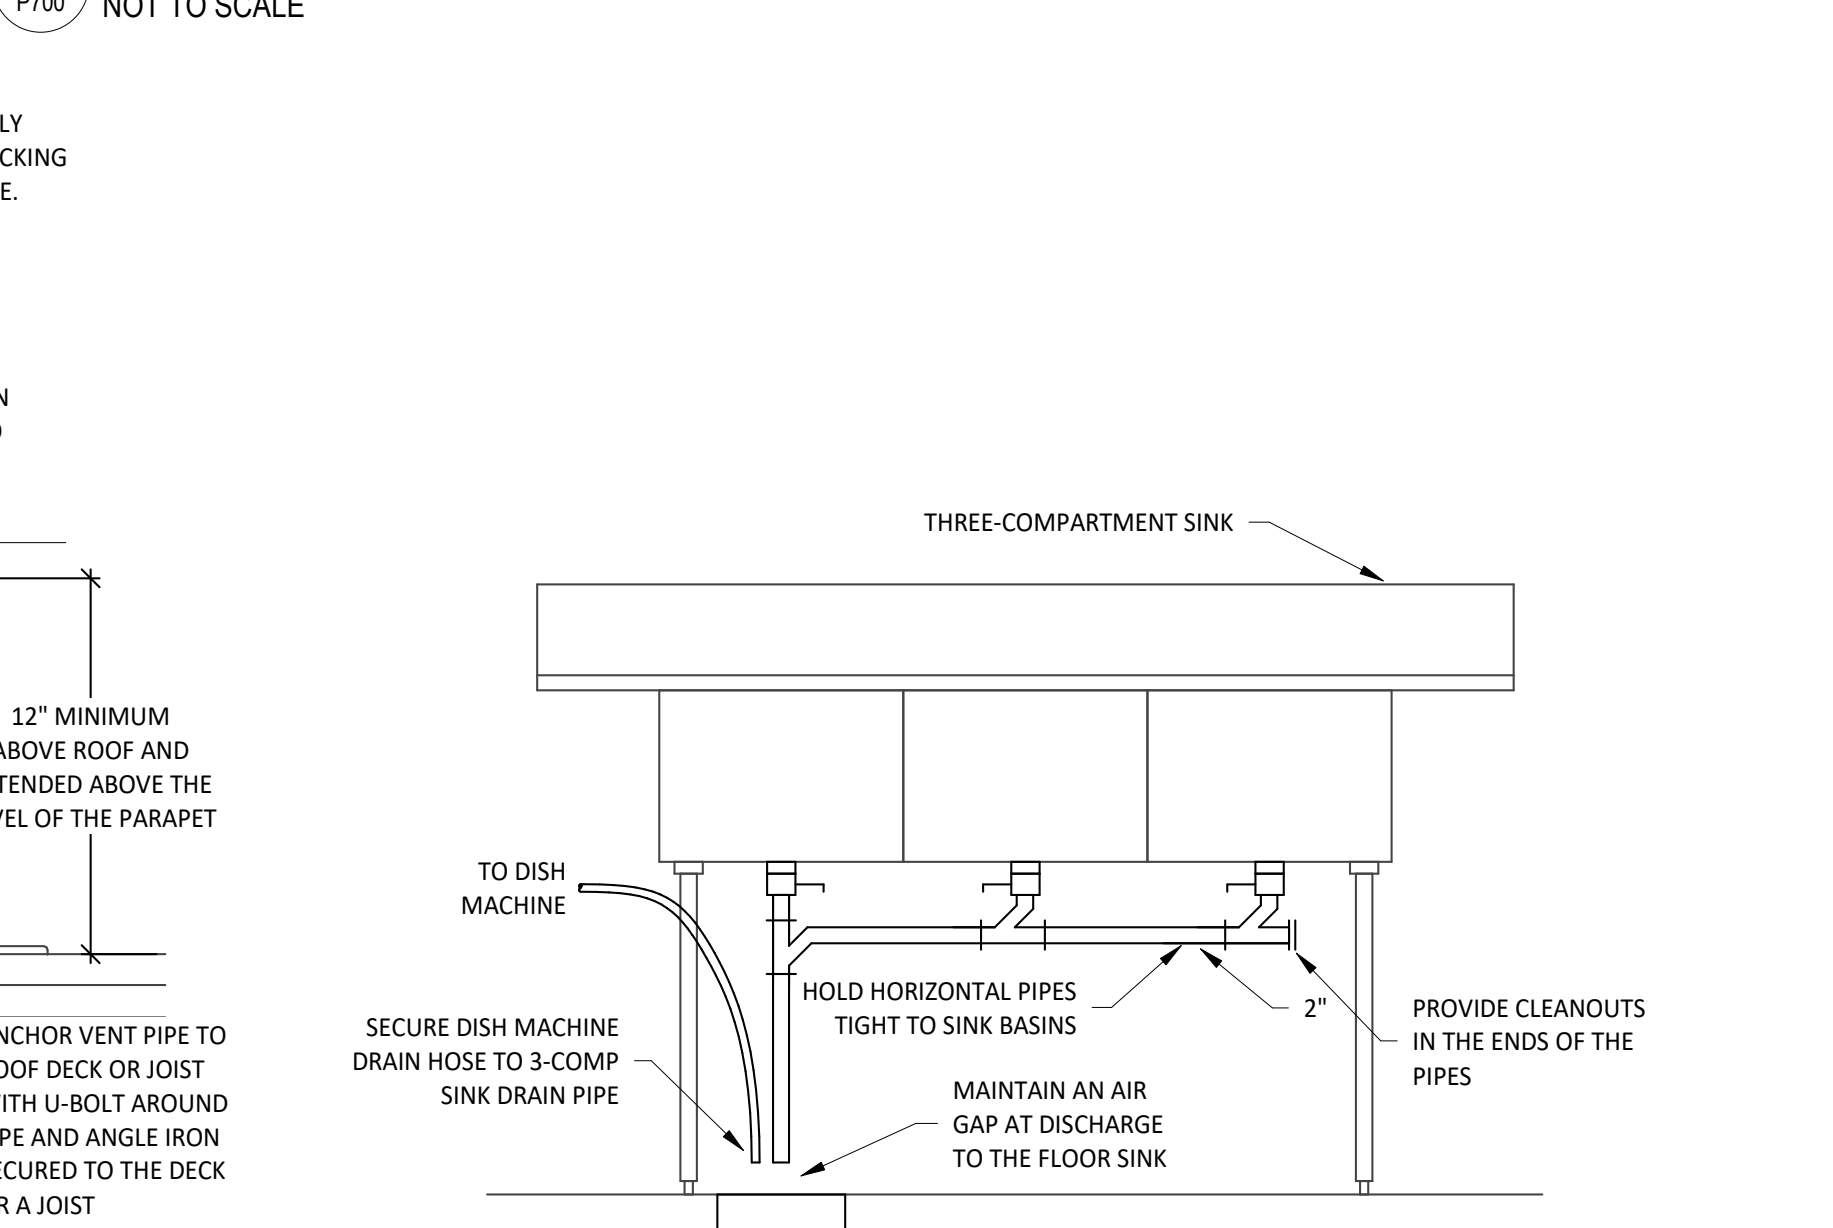


TO DISH MACHINE. SECURE DISH MACHINE DRAIN HOSE TO 3-COMP SINK DRAIN PIPE. HOLD HORIZONTAL PIPES TIGHT TO SINK BASINS. MAINTAIN AN AIR GAP AT DISCHARGE TO THE FLOOR SINK. PROVIDE CLEANOUTS IN THE ENDS OF THE PIPES. 2" FLOOR SINK. GREASE WASTE: SEE SHEET P110 FOR CONTINUATION.



2 WARE-WASHING SINK DETAIL
NOT TO SCALE

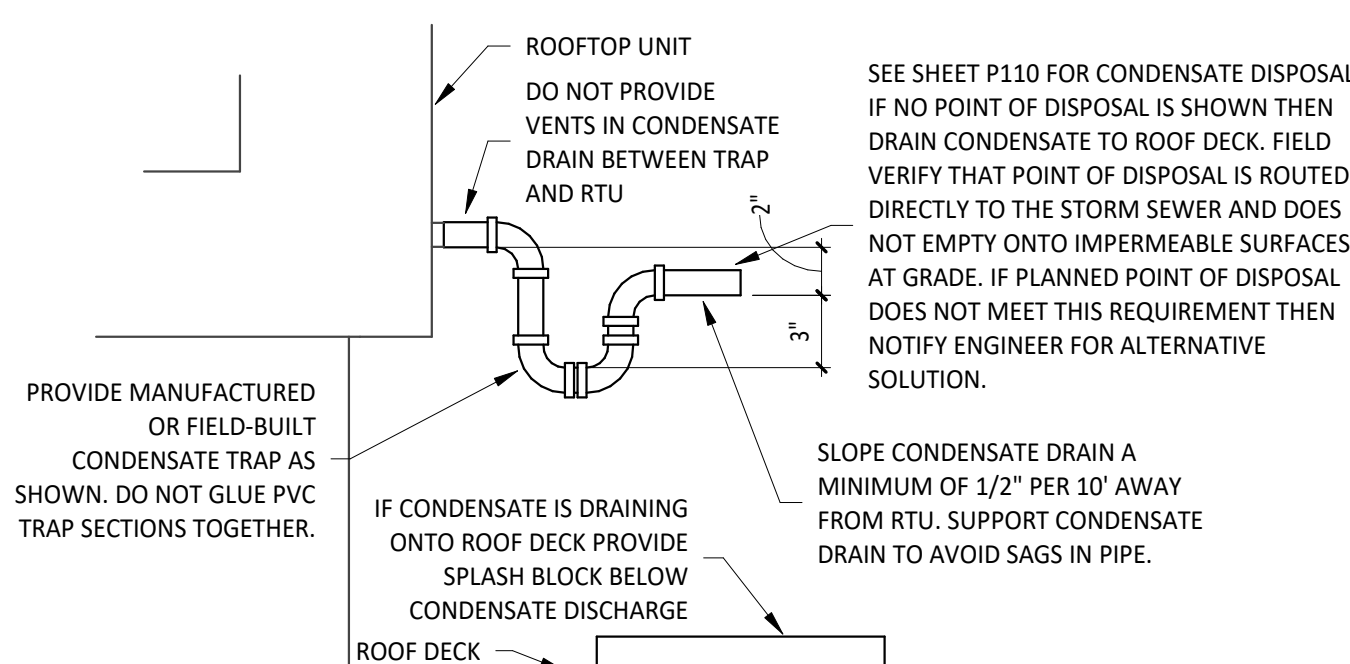

13 RTU CONDENSATE TRAP DETAIL
NOT TO SCALE


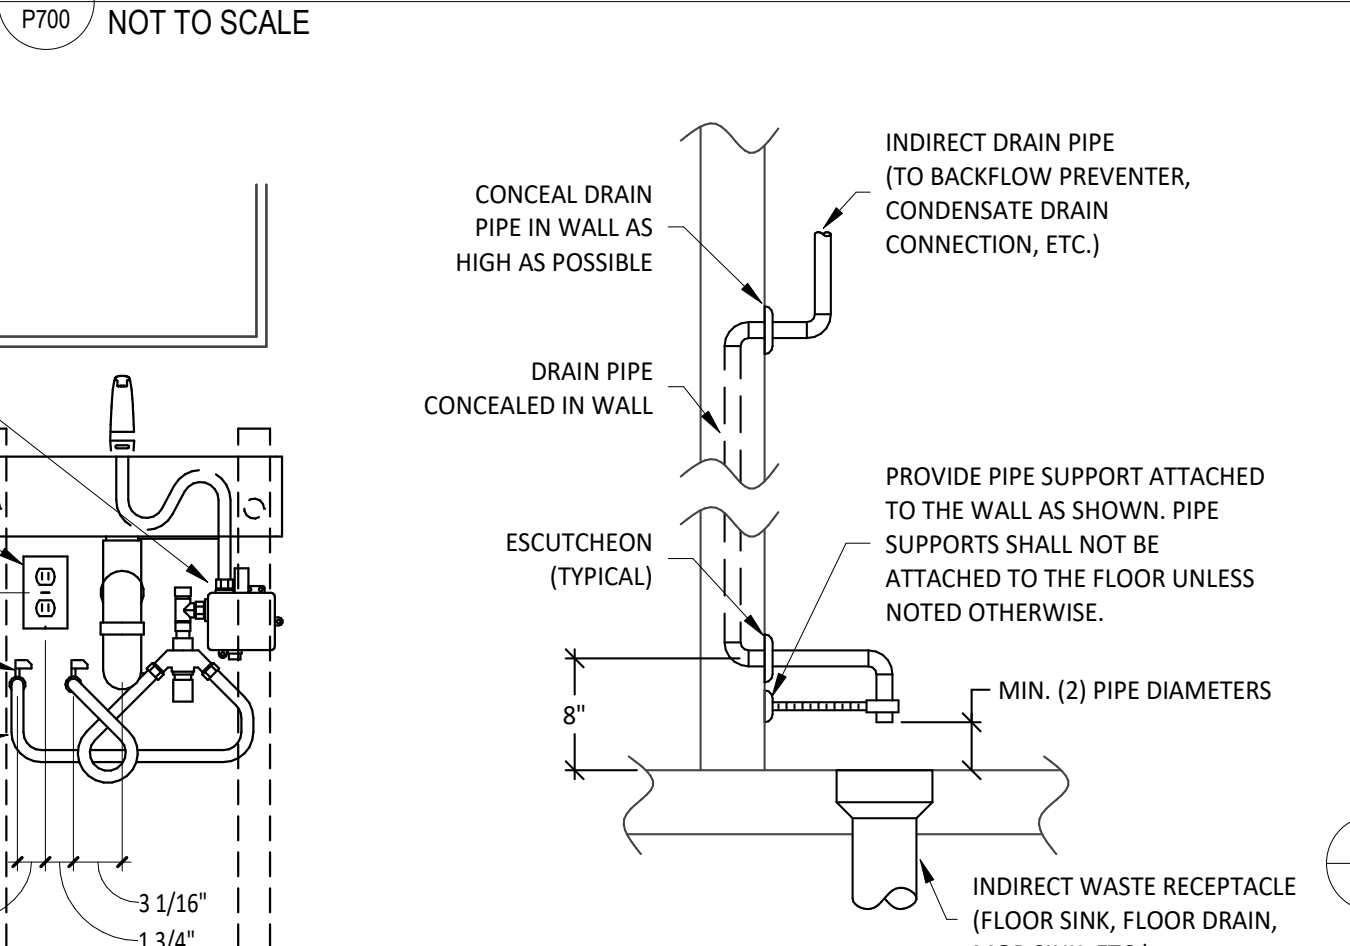


9 INDIRECT WASTE PIPING DETAIL
NOT TO SCALE

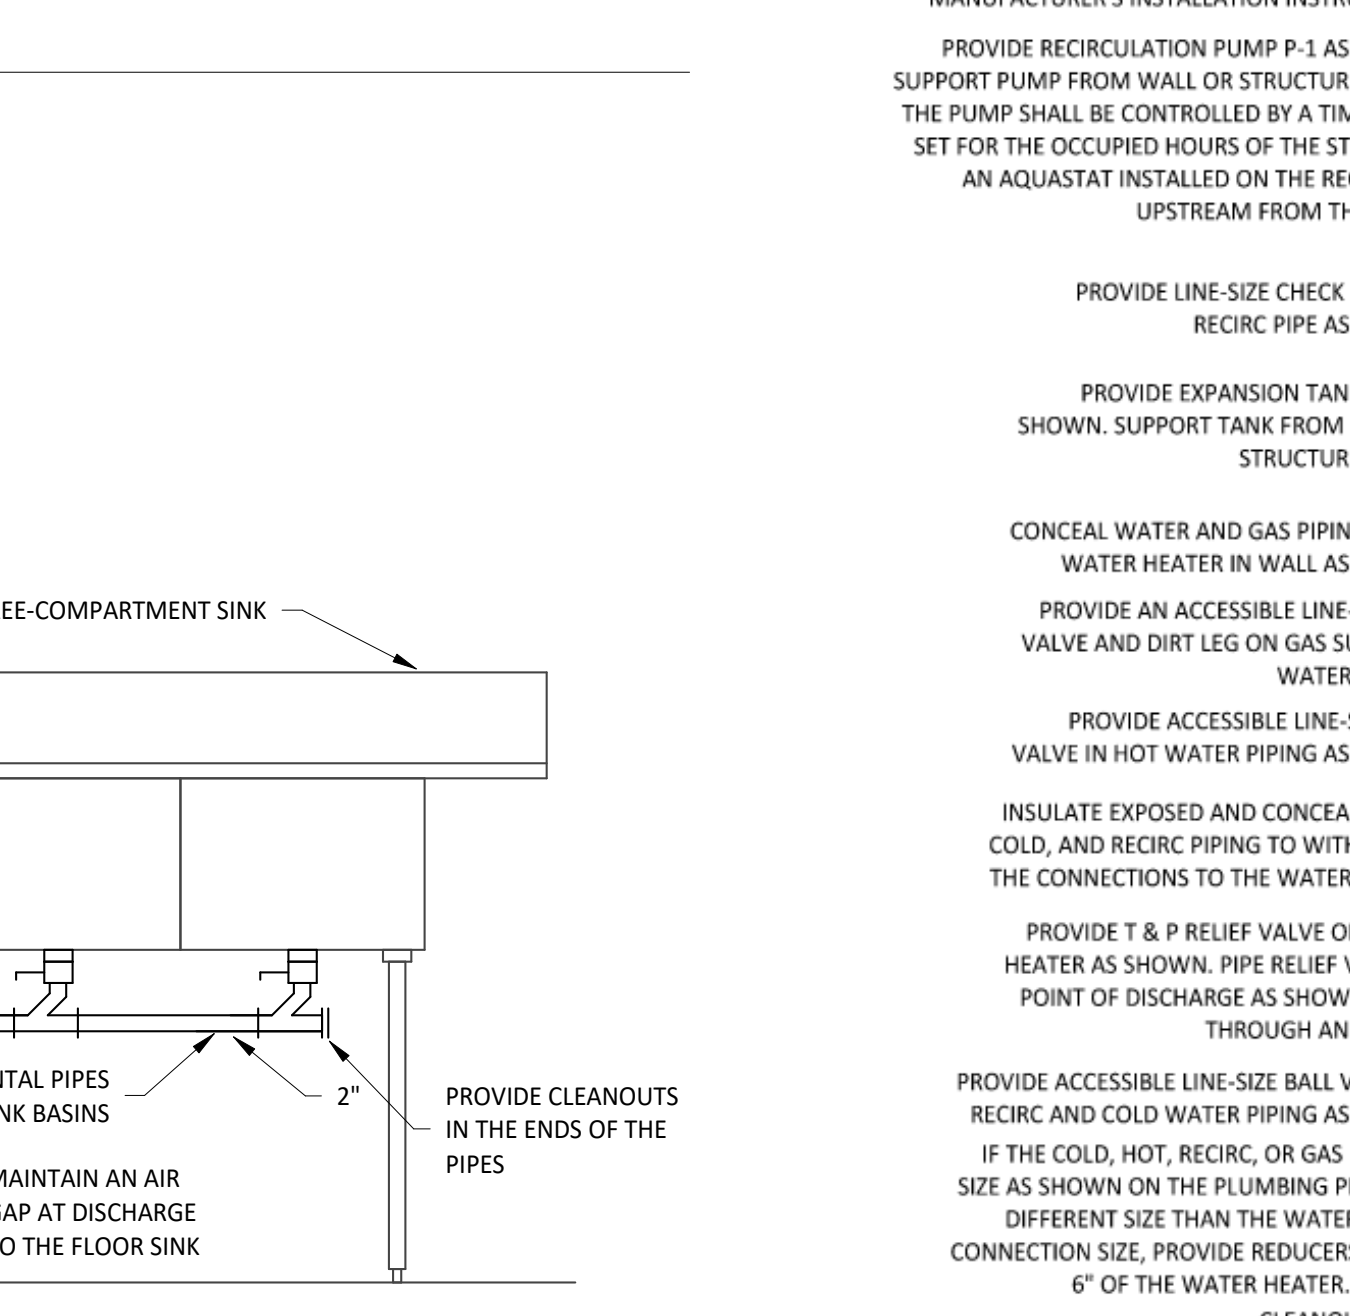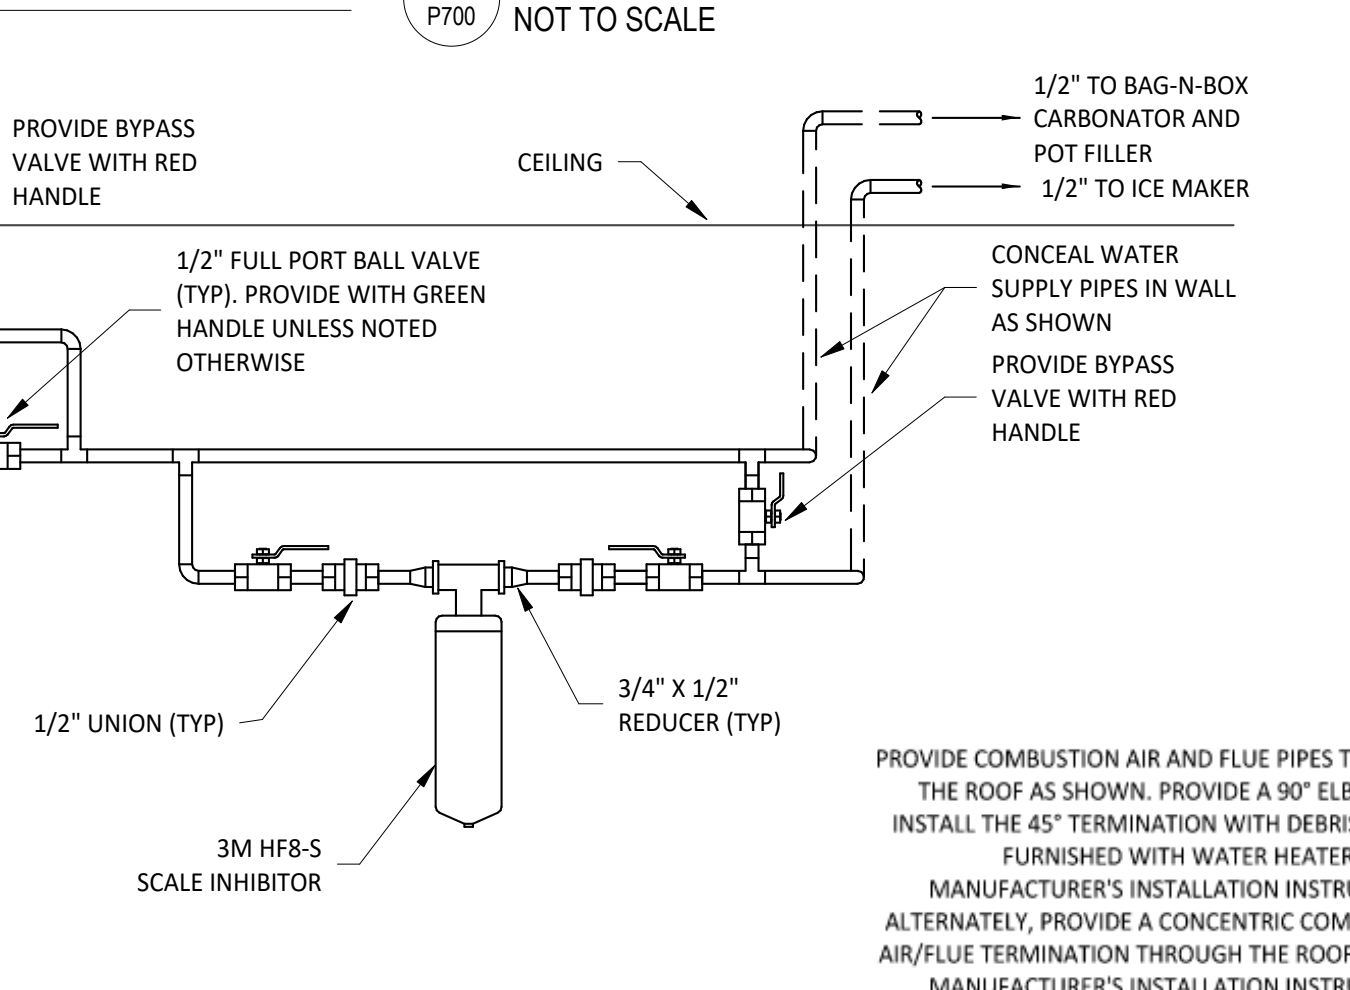


PROVIDE COMBUSTION AIR AND FLUE PIPES THROUGH THE ROOF AS SHOWN. PROVIDE A 90° ELBOW AND INSTALL THE 45° TERMINATION WITH DEBRIS SCREEN FURNISHED WITH WATER HEATER PER THE MANUFACTURER'S INSTALLATION INSTRUCTIONS. ALTERNATELY, PROVIDE A CONCENTRIC COMBUSTION AIR/FLUE TERMINATION THROUGH THE ROOF PER THE MANUFACTURER'S INSTALLATION INSTRUCTIONS. PROVIDE RECIRCULATION PUMP P-1 AS SHOWN. SUPPORT PUMP FROM WALL OR STRUCTURE ABOVE. THE PUMP SHALL BE CONTROLLED BY A TIME CLOCK SET FOR THE OCCURRED HOURS OF THE STORE AND AN AQUASTAT INSTALLED ON THE RECIRC PIPE UPSTREAM FROM THE PUMP. PROVIDE LINE-SIZE CHECK VALVE IN RECIRC PIPE AS SHOWN. PROVIDE EXPANSION TANK ET-1 AS SHOWN. SUPPORT TANK FROM WALL OR STRUCTURE ABOVE. CONCEAL WATER AND GAS PIPING ABOVE WATER HEATER IN WALL AS SHOWN. PROVIDE AN ACCESSIBLE LINE-SIZE GAS VALVE AND DIRT LEG ON GAS SUPPLY TO WATER HEATER. PROVIDE ACCESSIBLE LINE-SIZE BALL VALVE IN HOT WATER PIPING AS SHOWN. INSULATE EXPOSED AND CONCEALED HOT, COLD, AND RECIRC PIPING TO WITHIN 3" OF THE CONNECTIONS TO THE WATER HEATER. PROVIDE T & P RELIEF VALVE ON WATER HEATER AS SHOWN. PIPE RELIEF VALVE TO POINT OF DISCHARGE AS SHOWN. DRAIN THROUGH AN AIR GAP. PROVIDE ACCESSIBLE LINE-SIZE BALL VALVE ON RECIRC AND COLD WATER PIPING AS SHOWN. IF THE COLD, HOT, RECIRC, OR GAS PIPE LINE SIZE AS SHOWN ON THE PLUMBING PLANS IS A DIFFERENT SIZE THAN THE WATER HEATER CONNECTION SIZE, PROVIDE REDUCERS WITHIN 6" OF THE WATER HEATER. TYPICAL. CLEANOUT PANEL. CURB (SEE ARCHITECTURAL PLANS FOR DETAILS). PROVIDE 1/2" PVC FLUE CONDENSATE DRAIN FROM FLUE ELBOW TO POINT OF DISCHARGE AS SHOWN. DRAIN THROUGH AN AIR GAP.

1 WATER HEATER DETAIL
NOT TO SCALE

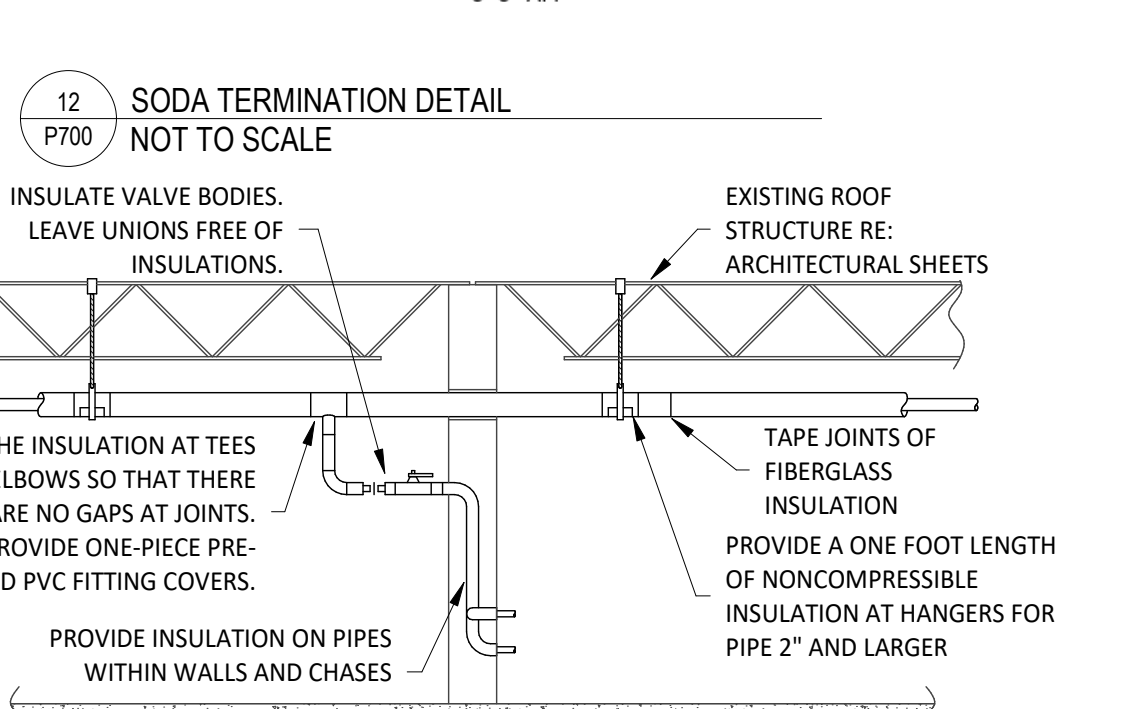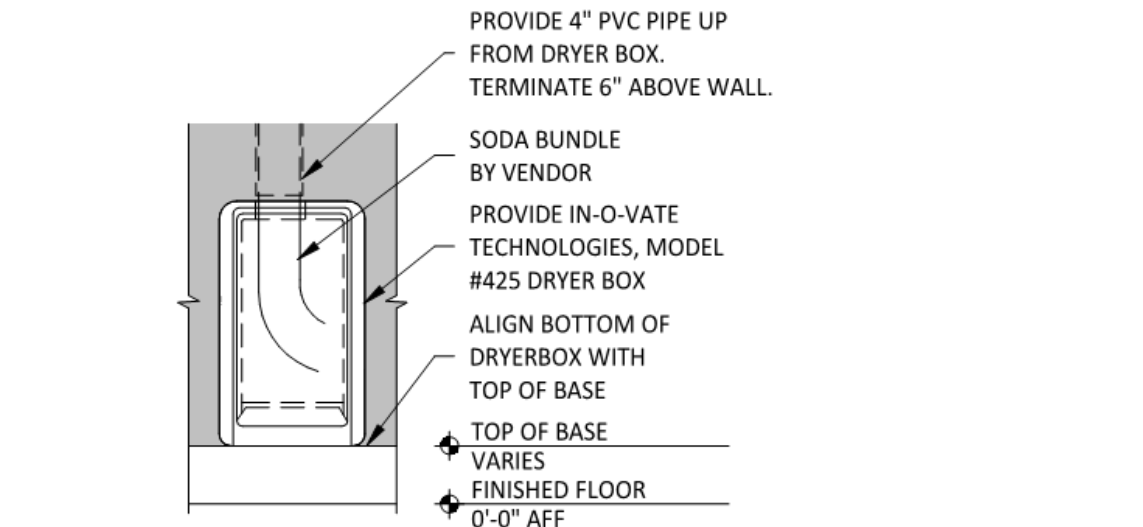

PROVIDE INSULATION ON INTERIOR COLD AND HOT WATER PIPING, CONDENSATE DRAIN PIPE, AND STORM PIPE. REFER TO SPECIFICATIONS FOR FURTHER INFORMATION REGARDING INSULATION. INSTALL ITEMS PER SPECIFICATIONS AND MANUFACTURER'S INSTRUCTIONS. MAINTAIN VAPOR BARRIER ON COLD WATER AND CONDENSATE PIPING BY MEANS OF SEALANT AND TAPE. FLAME SPREAD AND SMOKE-DEVELOPED INDEXES SHALL NOT EXCEED 25/50. SEAL EXPOSED ENDS OF FIBERGLASS INSULATION WITH ADHESIVE MASTIC. UNLESS NOTED OTHERWISE PROVIDE PREFORMED GLASS FIBER PIPE INSULATION WITH PRE-MOLDED PVC JACKETS, SLEEVES, AND FITTING COVERS ON EXPOSED WATER PIPE SO THAT EXPOSED WATER PIPE IS COVERED ENTIRELY WITH PVC INSULATION COVERS.

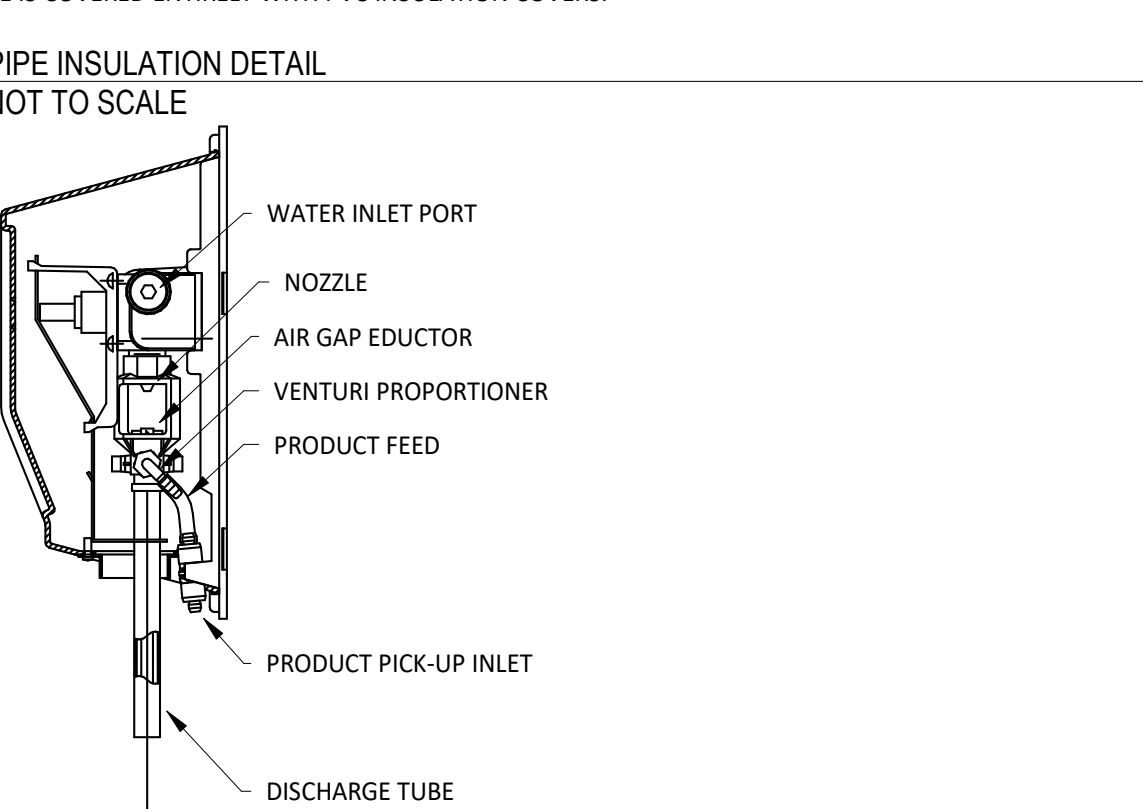

SECTION 16011 TEMPORARY & PERMANENT ELECTRICAL SERVICE

PART 1 - GENERAL

1.1 DEFINITIONS

- A. GFCI: Ground fault current interrupter.
B. RMS: Root Mean Square
C. SPD: Single Pole, Double Throw

1.2 USE CHARGES

- A. General: Cost or use charges for temporary facilities are not chargeable to Tenant, Architect, or Engineer and shall be included in the Contract Sum. Allow other entities to use temporary services and facilities without cost, including, but not limited to, the following:
- Tenant's construction forces.
 - Occupants of Project.
 - Architect.
 - Engineer.
 - Testing agencies.
 - Personnel of authorities having jurisdiction.
- B. Permanent Service: Coordinate with building Tenant and utility company to establish permanent service upon completion of the project. Contractor shall pay for all permits, aid-to-construction charges, and related fees associated with the new service.

1.3 NOTIFICATION

- A. Coordinate with Tenant to provide 72 hour written notification to other tenants of any power interruptions. Notification shall state the estimated time and duration of the electrical outage.

1.4 QUALITY ASSURANCE

- A. Standards: Comply with ANSI A10.6, NECA's "Temporary Electrical Facilities," and NFPA 241.
- Trade Jurisdictions: Assigned responsibilities for installation and operation of temporary utilities are not intended to interfere with trade regulations and union jurisdictions.
 - Electric Service: Comply with NECA, NEMA and UL standards and regulations for temporary electric service. Install service to comply with NFPA 70.
 - Comply with OSHA standards and regulations.

PART 2 PRODUCTS

2.1 MATERIALS

- A. Electrical Outlets: Properly configured, NEMA-polarized outlets to prevent insertion of 110- to 120-V plugs into higher-voltage outlets; equipped with ground-fault circuit interrupters, reset button, and pilot light.
- B. Power Distribution System Circuits: Where permitted and overhead and exposed for surveillance, wiring circuits, not exceeding 125-V ac, 20-A rating, and lighting circuits may be nonmetallic sheathed cable.
- C. Main panelboard with disconnect.
- D. Temporary lighting.
- E. 120 volt receptacles with overcurrent protection.
- F. Enclosures: NEMA AB 1 and NEMA KS 1 to meet environmental conditions of installed location.
- Outdoor Locations: NEMA 250, Type 3R.

PART 3 EXECUTION

3.1 INSTALLATION

- A. Electric Power Service: Provide weatherproof, grounded electric power service and distribution system of sufficient size, capacity, and power characteristics during construction period. Include meters, transformers, and overload-protected disconnecting means.
- Install power distribution wiring overhead and rise vertically where least exposed to damage.
- B. Electric Distribution: Provide receptacle outlets adequate for connection of power tools and equipment.
- Provide waterproof connectors to connect separate lengths of electrical power cords if single lengths will not reach areas where construction activities are in progress. Do not exceed safe length-voltage ratio.
 - Provide metal conduit, tubing, or metallic cable for wiring exposed to possible damage. Provide rigid steel conduits for wiring exposed on grades, floors, decks, or other traffic areas.
 - Provide metal conduit enclosures or boxes for wiring devices.
 - Provide 4-gang outlets, spaced so 1 DO-foot (30-m) extension cord can reach each area for power hand tools and task lighting. Provide a separate 125-V ac, 20-A circuit for each outlet.
- C. Lighting: Provide temporary lighting with local switching that provides adequate illumination for construction operations and traffic conditions.
- Install and operate temporary lighting that fulfills security and protection requirements without operating entire system.
 - Provide one 100-W incandescent lamp (or equivalent) every 50 feet (15 m) in traffic areas.
 - Install exterior-yard site lighting that will provide adequate illumination for construction operations, parking and traffic conditions, and signage visibility when the Work is being performed.

END OF SECTION 16011

SECTION 16060 - GROUNDING AND BONDING

PART 1 - GENERAL

1.1 SUMMARY

- A. This Section includes grounding of electrical systems and equipment. Grounding requirements specified in this Section may be supplemented by special requirements of systems described in other Sections.

1.2 QUALITY ASSURANCE

- A. Testing Agency Qualifications: Testing agency as defined by OSHA in 29 CFR 1910.7 or a member company of the International Electrical Testing Association and that is acceptable to authorities having jurisdiction.
- Testing Agency's Field Supervisor: Person currently certified by the International Electrical Testing Association to supervise on-site testing specified in Part 3.
- B. Electrical Components, Devices, and Accessories: Listed and labeled as defined in NFPA 70, Article 100, by a testing agency acceptable to authorities having jurisdiction, and marked for intended use.
- Comply with UL 467.

PART 2 - PRODUCTS

2.1 GROUNDING CONDUCTORS

- A. For insulated conductors, comply with Division 16 Section "Wiring Methods."
- B. Material: Copper.
- C. Equipment Grounding Conductors: Insulated with green-colored insulation.
- D. Grounding Electrode Conductors: Stranded cable.
- E. Bare Copper Conductors: Comply with the following:
- Solid Conductors: ASTM B 3.
 - Assembly of Stranded Conductors: ASTM B 8.

2.2 CONNECTOR PRODUCTS

- A. Comply with IEEE 837 and UL 467; listed for use for specific types, sizes, and combinations of conductors and connected items.

PART 3 - EXECUTION

3.1 APPLICATION

- A. Use only copper conductors.
- B. In raceways, use insulated equipment grounding conductors.
- C. Equipment Grounding Conductor Terminations: Use bolted pressure clamps.
- D. Grounding Bus: Install in electrical and telephone equipment rooms, in rooms housing service equipment, and elsewhere as indicated.
- Use insulated spacer; space 1 inch from wall and support from wall 6 inches above finished floor, unless otherwise indicated.
 - At doors, route the bus up to the top of the door frame, across the top of the doorway, and down to the specified height above the floor.

3.2 EQUIPMENT GROUNDING CONDUCTORS

- A. Comply with NFPA 70, Article 250, for types, sizes, and quantities of equipment grounding conductors, unless specific types, larger sizes, or more conductors than required by NFPA 70 are indicated.

3.3 INSTALLATION

- A. Grounding Conductors: Route along shortest and straightest paths possible, unless otherwise indicated. Avoid obstructing access or placing conductors where they may be subjected to strain, impact, or damage.

3.4 CONNECTIONS

- A. General: Make connections so galvanic action or electrolysis possibility is minimized. Select connectors, connection hardware, conductors, and connection methods so metals in direct contact will be galvanically compatible.
- B. Equipment Grounding Conductor Terminations: For No. 8 AWG and larger, use pressure-type grounding lugs. No. 10 AWG and smaller grounding conductors may be terminated with winged pressure-type connectors.
- C. Tighten screws and bolts for grounding and bonding connectors and terminals according to manufacturer's published torque-tightening values. If manufacturer's torque values are not indicated, use those specified in UL 486A.
- D. Compression-Type Connections: Use hydraulic compression tools to provide correct circumferential pressure for compression connectors. Use tools and dies recommended by connector manufacturer. Provide embossing die code or other standard method to make a visible indication that a connector has been adequately compressed on grounding conductor.

END OF SECTION 16060

SECTION 16100 - WIRING METHODS

PART 1 - GENERAL

1.1 SECTION REQUIREMENTS

- A. Summary: Building wire and cable and associated splices, connectors, and terminations for wiring systems rated 600 V and less, and twisted-pair cable; and raceways and boxes.

PART 2 - PRODUCTS

2.1 WIRES AND CABLES

- A. Connectors and Splices: Wiring connectors of size, ampacity rating, material, and type and class for application and for service indicated.

2.2 RACEWAYS

- A. Wireways: Screwed cover type, with manufacturers standard finish.
- B. Outlet and Device Boxes: Sheet metal boxes, except use cast-metal boxes at exterior, interior exposed, and interior damp locations.
- C. Pull and Junction Boxes: Sheet metal boxes, except use nonmetallic boxes with gasketed covers at exterior and interior damp locations.
- D. ENCLOSURES
- A. Hinged-Cover Enclosures: NEMA 250, steel enclosure with continuous hinge cover and flush latch. Finish inside and out with manufacturer's standard enamel.
- B. Cabinets: NEMA 250, Type 1, unless otherwise indicated.

PART 3 - EXECUTION

3.1 INSTALLATION

- A. Install wires and cables according to the NECA's "Standard of Installation.
- B. Wiring at Outlets: Install with at least 12 inches of slack conductor at each outlet.
- C. Conceal wiring, unless otherwise indicated, within finished walls, ceilings, and floors.
- D. Boxes and Enclosures: In damp or wet locations use NEMA 250, Type 4, stainless steel.
- E. Use raceway fittings compatible with raceway and suitable for use and location. For intermediate metal conduit, use threaded rigid steel conduit fittings, unless otherwise indicated.
- F. Raceways Embedded in Slabs: Install in middle third of the slab thickness where practical, and leave at least 1-inch concrete cover.
- G. Install exposed raceways parallel to or at right angles to nearby surfaces or structural members, and follow the surface contours as much as practical.
- H. Join raceways with fittings designed and approved for the purpose and make joints tight. Use bonding bushings or wedges at connections subject to vibration. Use bonding jumpers where joints cannot be made tight. Use insulating bushings to protect conductors.
- I. Install pull wires in empty raceways. Use No. 14 AWG zinc-coated steel or monofilament plastic line having not less than 200-lb tensile strength. Leave not less than 18 inches of slack at each end of the pull wire.
- J. Install raceway sealing fittings where required by the NEC and at wiring entrances to refrigerated spaces. Locate at suitable, approved, accessible locations and fill them with UL-listed sealing compound. For concealed raceways, install each fitting in a flush steel box with a blank cover plate having a finish similar to that of adjacent plates or surfaces.
- K. Stub-up Connections for Equipment: Extend conductors to equipment with rigid metal conduit; flexible metal conduit may be used 3 inches above the floor.
- L. Install a separate green ground conductor in surface metal raceway from the junction box supplying the raceway to receptacle and fixture ground terminals.

3.2 IDENTIFICATION MATERIALS AND DEVICES

- A. Install at locations for most convenient viewing without interference with operation and maintenance of equipment.
- B. Coordinate names, abbreviations, colors, and other designations used for electrical identification with corresponding designations indicated in the Contract Documents or required by codes and standards. Use consistent designations throughout Project.
- C. Identify raceways and cables with color banding as follows:
- Bands: Pretensioned, snap-around, colored plastic sleeves or colored encircling conduit, and place adjacent bands of two-color markings in contact, side by side.
 - Band Locations: At changes in direction, at penetrations of walls and floors, at 50-foot maximum intervals in straight runs, and at 25-foot maximum intervals in congested areas.
 - Colors: As follows:
 - Telecommunication System: Green and yellow.
- D. Color-code System secondary service, feeder, and branch-circuit conductors throughout the secondary electrical system as follows:

	120/208V	277/480V
1. Phase A:	Black	Brown
2. Phase B:	Red	Orange
3. Phase C:	Blue	Yellow
4. Neutral:	White	Gray
5. Ground:	Green	Green

END OF SECTION 16100

SECTION 16140 - WIRING DEVICES

PART 1 - GENERAL

1.1 SECTION REQUIREMENTS

- A. Submittals: None.
- B. Comply with NEMA WD 1.
- C. Comply with NFPA 70.

PART 2 - PRODUCTS

2.1 DEVICES

- A. General: Listed and labeled as defined in NFPA 70, Article 100, by a testing agency acceptable to authorities having jurisdiction.
- B. Color: Per Material Schedule on sheet E010.
- C. Receptacles: Heavy- Duty grade, NEMA WD6, Configuration 5-20R unless otherwise indicated.
- D. Ground-Fault Circuit Interrupter Receptacles: integral duplex receptacle; for installation in box without an adapter.
- E. Feed-through type, with a 2-3/4-inch- deep outlet
- E. Isolated-Ground Receptacles: Equipment grounding contacts connected only to the green grounding screw terminal of the device with inherent electrical isolation from mounting strap.
- F. Snap Switches: Heavy-duty, quiet type.
- G. Wall Plate: Per Material Schedule on sheet E010.
- H. Floor Service Fittings: Modular, above-floor, dual-service units suitable for wiring method used.
- PART 3 - EXECUTION
- 3.1 INSTALLATION
- A. Install devices and assemblies plumb and secure.
- B. Mount devices flush with long dimension vertical unless otherwise indicated.
- C. Protect devices and assemblies during painting.
- D. Install wall plates when painting is complete and paint is cured.

END OF SECTION 16140

SECTION 16442 - PANELBOARDS

PART 1 - GENERAL

1.1 SECTION REQUIREMENTS

- A. Submittals: None.
- B. Comply with NFPA 70.
- C. Comply with NEMA PB 1.

PART 2 - PRODUCTS

2.1 PANELBOARDS AND LOAD CENTERS

- A. Manufacturers: Subject to compliance with requirement, provide products by one of the following:
- Panelboards, Overcurrent Protective Devices, Controllers, Contactors, and Accessories:
 - Square D Co.
 - Eaton Corp.; Cutler-Hammer Products.
 - General Electric Co.; Electrical Distribution & Control Div.
 - Siemens Energy & Automation.
 - Recessed, NEMA 3R.
 - Panelboard Capacity: as shown on drawings.
 - Service entrance rated.
 - Front: Secured to box with concealed concealed fasteners.
 - Doors: With concealed hinges, handle latch, padlock clamp.
 - Bus: Hard drawn copper of 98 percent conductivity.
 - Recessed, NEMA PB 1, Type 1.
 - Load Center Capacity: as shown on drawings.
 - Front: Secured to box with concealed trim clamps.
 - Doors: With concealed hinges, flush catches, and tumbler locks, all keyed alike.
 - Bus: Hard drawn copper of 98 percent conductivity.
 - Molded-Case Circuit Breakers: NEMA AB 1, plug-in type, Single-handle for multipole circuit breakers. Appropriate for application, including Type SWD for repetitive switching lighting loads and Type HACR for heating, air-conditioning, and refrigerating equipment.
 - Contactors: NEMA ICS 2, Class A combination contactors.
- PART 3 - EXECUTION
- 3.1 INSTALLATION
- A. Install panelboards and accessory items according to NEMA PB 1.1. Provide typed, permanently-mounted English and Spanish circuit directories showing the panel schedules as installed in each panelboard.
- B. Mounting Heights: Top of trim 74 inches above finished floor, unless otherwise indicated.
- C. Future Circuit Provisions at Flush Panel boards: Stub four empty 3/4-inch conduits from panelboard into accessible or designated ceiling space.
- D. Wiring in Panelboard Gutters: Arrange conductors into groups, bundle and wrap with wire ties according to NEC guidelines.
- E. Tighten electrical connectors and terminals, including grounding connections, according to manufacturer's published torque-tightening values. Where manufacturer's torque values are not indicated, use those specified in UL 486A.
- F. Perform visual and mechanical inspections and electrical tests stated in NETA ATS.

END OF SECTION 16442

SECTION 16500 - LIGHTING

PART 1 - GENERAL

1.1 SECTION REQUIREMENTS

- A. Submittals: None.
- B. Fixtures, Emergency Lighting Units, and Accessories: Listed and labeled as defined in NFPA 70, Article 100, by a testing agency acceptable to authorities having jurisdiction.
- C. Coordinate ceiling-mounted luminaires with ceiling construction, mechanical work, and security and fire-prevention features mounted in ceiling space and on ceiling.

PART 2 - PRODUCTS

2.1 FIXTURES AND FIXTURE COMPONENTS, GENERAL

- A. Metal Parts: Free from burrs, sharp corners, and edges. Steel, unless otherwise indicated. Form and support to prevent warping and sagging.
- B. Doors, Frames, and Other Internal Access: Smooth operating, free from light leakage under operating conditions, and arranged to permit re-lamping without use of tools. Arrange doors, frames, lenses, diffusers, and other pieces to prevent accidental falling during re-lamping and when secured in operating position.
- C. Lenses, Diffusers, Covers, and Globes: 100 percent virgin acrylic plastic or annealed crystal glass, unless otherwise indicated.

PART 3 - EXECUTION

3.1 INSTALLATION

- A. Set units level, plumb, and square with ceiling and walls, and secure.
- B. Support for Recessed and Semi-recessed Grid-Type Fluorescent Fixtures: Install ceiling support system rods or wires at a minimum of 4 rods or wires for each fixture, located not more than 6 inches from fixture corners.
- C. Support for Suspended Fixtures: Support according to manufacturers' recommendations.
- D. Lamping: Where specific lamp designations are not indicated, lamp units according to manufacturer's written instructions.

END OF SECTION 16500

ELECTRICAL SYMBOLS

	CONDUIT CONCEALED ABOVE THE CEILING, IN A WALL, OR IN A RACEWAY
	CONDUIT CONCEALED BELOW THE SLAB
	HOME-RUN TO PANELBOARD AND CIRCUIT NUMBER SHOWN
	PLAN NOTE: SEE PLAN NOTES LISTED ON THE SAME SHEET FOR NOTE MEANING
	HALFTONED FIXTURES DENOTES EXISTING PHASE AND PROVIDED UNDER SEPARATE CONTRACT
	DISCONNECT SWITCH: X = SWITCH RATING Y = FUSE SIZE (NF = NON-FUSED) Z = NUMBER OF POLES
	JUNCTION BOX
	ELECTRIC PANELBOARD
	GENERAL PURPOSE 1-POLE SWITCH
	MANUAL STARTER WITH PILOT LIGHT
	NEMA 5-20R 1-PLEX RECEPTACLE
	NEMA 5-20R DUPLEX RECEPTACLE
	NEMA 5-20R DOUBLE-DUPLEX RECEPTACLES
	NEMA 5-20R DUPLEX COMBINATION ISOLATED GROUND/GFI RECEPTACLE PASS & SEYMOUR MODEL#209SIGTRGRY (GRAY) OTHER RECEPTACLE - SEE PLAN FOR RATING AND TYPE
	JUNCTION BOX FOR RJ-45 DATA OUTLETS. PROVIDE 1" CONDUIT WITH PULL STRING FROM J-BOX TO ABOVE OFFICE CEILING. TERMINATE CONDUIT WITH CONDUIT BUSHING.
	DOUBLE GANG JUNCTION BOX FOR RJ-45 DATA OUTLETS. PROVIDE 1" CONDUIT WITH PULL STRING FROM J-BOX TO ABOVE OFFICE CEILING. TERMINATE CONDUIT WITH CONDUIT BUSHING.
	JUNCTION BOX FOR RJ-11 TELEPHONE OUTLETS. PROVIDE 1" CONDUIT WITH PULL STRING FROM J-BOX TO ABOVE OFFICE CEILING. TERMINATE CONDUIT WITH CONDUIT BUSHING.
	SECURITY SYSTEM KEYPAD: PROVIDE A RECESSED JB WITH A 1/2" CONDUIT TO ABOVE THE DROP TILE CEILING IN THE OFFICE AREA AND TERMINATE WITH A CONDUIT BUSHING

ELECTRICAL MATERIAL SCHEDULE		
TYPE	APPLICATION	ALLOWABLE MATERIAL
CONDUCTORS	#8 AWG AND LARGER	STRANDED CU, TYPE THHN/THWN OR XHHW
	#10 AWG AND SMALLER	SOLID CU, TYPE THHN/THWN OR XHHW
	FIELD-MADE CORD (EXPOSED INDOOR LOCATIONS)	TYPE SO OR SJO SERVICE CORD WITH CU CONDUCTORS
CONDUITS	CONNECTION TO VIBRATION EQUIPMENT (EXPOSED INDOOR DRY LOCATIONS)	FLEXIBLE METAL CONDUIT
	CONNECTION TO VIBRATION EQUIPMENT (EXPOSED WET OR DAMP LOCATIONS)	LIQUIDTIGHT FLEXIBLE METAL CONDUIT
	INDOOR, CONCEALED ABOVE GRADE	ELECTRICAL METALLIC TUBING, FLEXIBLE METAL CONDUIT, OR METAL CLAD CABLE
	INDOOR, EXPOSED	ELECTRICAL METALLIC TUBING U.N.O.
	INDOOR, WITHIN 1-1/2" OF ROOF DECK OR LOW OR LINE VOLTAGE, BELOW GRADE	INTERMEDIATE METAL CONDUIT (SCHEDULE 40 PVC)
	LOW VOLTAGE INDOOR, ABOVE GRADE OUTDOOR, ABOVE GRADE, EXPOSED OR CONCEALED	ELECTRICAL METALLIC TUBING INTERMEDIATE METAL CONDUIT
WIRING DEVICES	IG OR IG/GFI RECEPTACLES	GRAY DEVICE WITH STAINLESS STEEL COVER PLATE
	IN KITCHEN, OFFICE OR NON-PUBLIC SPACES	GRAY DEVICE WITH STAINLESS STEEL COVER PLATE
	IN RESTROOMS	WHITE DEVICE WITH WHITE COVER PLATE
	ON DRYWALL IN DINING ROOM	WHITE DEVICE WITH WHITE COVER PLATE
	ON HOT ROLLED STEEL, RICHLUITE OR OTHER BLACK FINISHES	BLACK DEVICE WITH BLACK COVER PLATE

Signage shown on the drawings is under a separate permit review


ELECTRICAL ABBREVIATIONS

(E)	EXISTING
ABV	ABOVE
ADA	AMERICANS WITH DISABILITIES ACT
AFF	ABOVE FINISHED FLOOR
AFG	ABOVE FINISHED GRADE
AHJ	AUTHORITY HAVING JURISDICTION
BFF	BELOW FINISHED FLOOR
BFG	BELOW FINISHED GRADE
BOH	BACK OF HOUSE
CLG	CEILING
CTE	CONNECT TO EXISTING
DN	DOWN
EXTG	EXISTING
FLR	FLOOR
FOH	FRONT OF HOUSE
GFCI	GROUND FAULT CURRENT INTERRUPTER
GYP	GYPSPUM BOARD
IG	ISOLATED GROUND
NF	NON-FUSED
NL	NIGHT LIGHT
NTS	NOT TO SCALE
OH	OVERHEAD
TYP	TYPICAL
UG	UNDERGROUND
UNO	UNLESS NOTED OTHERWISE
W/	WITH
WIC	WALK-IN COOLER
WP	WEATHERPROOF

C02AS	TENANT'S C02 ALARM SUPPLIER
GC	GENERAL CONTRACTOR
HES	TENANT'S HVAC EQUIPMENT SUPPLIER
HS	TENANT'S HOOD SUPPLIER
KES	TENANT'S KITCHEN EQUIPMENT SUPPLIER
LL	LANDLORD
MSS	TENANT'S MUSIC SYSTEMS SUPPLIER
SPS	TENANT'S SODA POP SUPPLIER
TAB	TENANT'S TEST AND BALANCE VENDOR
TCC	TENANT'S CABLING CONTRACTOR
TDC	TENANT'S DUCT CLEANER
TEMS	TENANT'S ENERGY MANAGEMENT SYSTEM SUPPLIER
TLS	TENANT'S LIGHT/LAMP SUPPLIER
TMB	TENANT'S MENU BOARD SUPPLIER
TMS	TENANT'S MILLWORK SUPPLIER
TP	TENANT'S PHONE SUPPLIER
TPS	TENANT'S PANELBOARD SUPPLIER
TRS	TENANT'S RAILING SUPPLIER
TSV	TENANT'S SIGN VENDOR
TUV	TENANT'S UV SANITIZER SUPPLIER
WCS	TENANT'S WALK-IN COOLER SUPPLIER
WHS	TENANT'S WATER HEATER SUPPLIER

Consultant:

AYRES
MECHANICAL, ELECTRICAL,
PLUMBING (MEP)
1700 West Highway 36 - Suite 700
Roseville, Minnesota 55113
(651) 639-9606 Fax (651) 639-9618
Project No. 81-0606

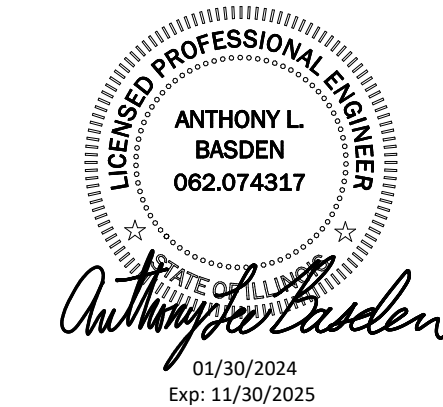

COPYRIGHT 2024
THIS DRAWING IS AN INSTRUMENT OF SERVICE AND AS SUCH REMAINS THE PROPERTY OF CHIPOTLE MEXICAN GRILL, INC. PERMISSION FOR USE OF THIS DOCUMENT IS LIMITED AND CAN BE EXTENDED ONLY BY WRITTEN AGREEMENT WITH CHIPOTLE MEXICAN GRILL, INC.



CHIPOTLE MEXICAN GRILL, INC.
PO BOX 182566
COLUMBUS, OH 43218-2566
(614) 318-2400
www.chipotle.com

STORE NO.: 5037
"HUNTLEY"
12990 ROUTE 47, LOT 4B
HUNTLEY, IL 60142

Issue Record:	PERMIT SUBMITTAL
01/30/2024	BID SET
03/15/2024	CONSTRUCTION SET
05/03/2024	

Revisions:	CITY COMMENTS
03/07/24	

Drawn:	Checked:
AJA	ALB

Project No.

2023-0175

Contents:

ELECTRICAL SPECIFICATIONS

E010

LIGHTING CONTROL PANEL SCHEDULE: LCP

RELAY	PANEL	CIRCUIT	AREA SERVED	CONTROL	TIME ON	TIME OFF	DIMMER CONTROL	NOTES
R1	A	32	KITCHEN A	TIMECLOCK	7:00:00 AM	12:00:00 AM	N/A	SINGLE POLE (NC)
R2	A	32	KITCHEN B	TIMECLOCK	7:00:00 AM	12:00:00 AM	N/A	SINGLE POLE (NC)
R3			SPARE					SINGLE POLE (NC)
R4	A	30	DINING ROOM A	TIMECLOCK	10:00:00 AM	12:00:00 AM	N/A	SINGLE POLE (NC)
R5	A	30	DINING ROOM B	TIMECLOCK	10:00:00 AM	12:00:00 AM	N/A	SINGLE POLE (NC)
R6	A	30	DINING ROOM DL	TIMECLOCK	10:00:00 AM	12:00:00 AM	N/A	SINGLE POLE (NC)
R7	A	28	RESTROOM EXHAUST FAN	TIMECLOCK	7:00:00 AM	12:00:00 AM	N/A	SINGLE POLE (NC)
R8	A	40	EXT. LIGHTING/SIGNAGE	TIMECLOCK	SUNSET - 1 HR	12:00:00 AM	N/A	SINGLE POLE (NC)

LIGHTING CONTROL PANEL SCHEDULE NOTES

A. DUPLICATE PANEL SCHEDULE AND PERMANENTLY INSTALL WITHIN THE LIGHTING CONTROL PANEL.

LIGHTING CONTROL COMPONENTS SCHEDULE

	DESCRIPTION	QUANTITY	FURNISHED BY	INSTALLED BY	MANUFACTURER	MODEL	REMARKS
LCP	DLIGHT LIGHTING CONTROL PANEL	1	TLS	GC	ACUITY	ARP INTENC08 NLT 8SPR MVOLT FM DTC	8 RELAY PANEL FOR ON/OFF CONTROL WITH FLUSH MOUNT ENCLOSURE, AND DIGITAL TIME CLOCK
\$C	WALL-MOUNTED OVERRIDE SWITCH	1	TLS	GC	ACUITY	nPODMA 4P	SEE LIGHTING CONTROL DIAGRAM FOR SWITCH CONFIGURATION
\$D	WALL-MOUNTED DIMMER SWITCH	2	TLS	GC	COOPER	SALO6P-W	SLIDE DIMMER COMPATIBLE WITH UP TO 300W LED LIGHTING. SET AT 50%. IF DINING ROOM LIGHTS FLICKER AT THIS DIMMER SETTING THEN GC SHALL PROVIDE LUTRON DVCL-253P DIMMER AS REPLACEMENT.
\$OC	WALL-MOUNTED LINE VOLTAGE OCCUPANCY SENSOR	4	TLS	GC	HUBBELL	LHMTS 1-N-WH	WHITE DUAL TECHNOLOGY SINGLE RELAY WITH 1 BUTTON AND NEUTRAL WIRING

LIGHTING FIXTURE SCHEDULE

TAG	COUNT	DESCRIPTION	MOUNTING	VOLTAGE	WATTS	FURNISHED BY	INSTALLED BY	BASIS FOR DESIGN			REMARKS
								MANUFACTURER	MODEL	LAMP	
A1	11	2x2 LED LENSED TROFFER	LAY-IN	120 V	30 W	TLS	GC	NORA LIGHTING	NPDBL-E22/334 W	INTEGRAL 3000K LED	COMPATIBLE WITH 0-10V DIMMING, FACTORY LOCKED TO 3000K
B1	7	RECESSED 6IN CAN LIGHT	CEILING	120 V	17 W	TLS	GC	NORA LIGHTING	NHIC-6G24ATFL W/ NTM-57W/M1 TRIM	(1) 17W ECOSTORY ECO-PAR38C-17-GU24-27 K-25D LED (25°-2700K) W/ GU 24 BASE	
B2	36	RECESSED 6IN CAN LIGHT W/ LED TRIM	CEILING	120 V	17 W	TLS	GC	NORA LIGHTING	NHIC-6G24ATFL WITH NLBCB-65130WW LED TRIM	INTEGRAL 3000K LED	LED TRIM FURNISHED WITH GU24 SOCKET ADAPTER
B3	4	RECESSED 6IN CAN LIGHT W/ BLACK LED TRIM	CEILING	120 V	12 W	TLS	GC	NORA LIGHTING	NHIC-6G24ATFL WITH NLBCB2-65127B8 LED TRIM	INTEGRAL 3000K LED	BLACK LED TRIM FURNISHED WITH GU24 SOCKET ADAPTER
C0	2	LOW PROFILE LED - 1 FT	SURFACE	120 V	5 W	TLS	GC	HERA LIGHTING	EL/LED/12/WWW	INTEGRAL 3000K LED	FURNISHED WITH COVERS, CONNECTORS, AND ONE HARDWIRE BOX OR CORD/PLUG PER SECTION
C2	6	LOW PROFILE LED - 3 FT	SURFACE	120 V	12 W	TLS	GC	HERA LIGHTING	EL/LED/34/WWW	INTEGRAL 3000K LED	FURNISHED WITH COVERS, CONNECTORS, AND ONE HARDWIRE BOX OR CORD/PLUG PER SECTION
C3	6	LOW PROFILE LED - 4 FT	SURFACE	120 V	15 W	TLS	GC	HERA LIGHTING	EL/LED/46/WWW	INTEGRAL 3000K LED	FURNISHED WITH COVERS, CONNECTORS, AND ONE HARDWIRE BOX OR CORD/PLUG PER SECTION
C4	8	LOW PROFILE LED - 5 FT	SURFACE	120 V	18 W	TLS	GC	HERA LIGHTING	EL/LED/59/WWW	INTEGRAL 3000K LED	FURNISHED WITH COVERS, CONNECTORS, AND ONE HARDWIRE BOX OR CORD/PLUG PER SECTION
E1	4	EMERGENCY LIGHT - DUAL HEAD	VARIOUS	120 V	2 W	TLS	GC	EXITRONIX	LED-90	INTEGRAL LED	90 MINUTE BATTERY BACKUP
E2	4	EXTERIOR REMOTE EMERGENCY LIGHT	VARIOUS	4 V	1 W	TLS	GC	EXITRONIX	CLED-BL-WP WITH PMC-B-1 MOUNTING PLATE	INTEGRAL LED	LOW VOLTAGE REMOTE EMERGENCY LIGHT POWERED BY REMOTE-CAPABLE EXIT SIGN
E4	5	WHITE EXIT SIGN WITH EMERGENCY LIGHT -STANDARD RED LETTERS	VARIOUS	120 V	2 W	TLS	GC	EXITRONIX	CLED-U-WH	INTEGRAL LED	90 MINUTE BATTERY BACKUP WITH INTEGRAL EMERGENCY LIGHT, REMOTE HEAD CAPABLE
E7	8	EMERGENCY LIGHT	VARIOUS	120 V	2 W	TLS	GC	EXITRONIX	EV2	INTEGRAL LED	90 MINUTE BATTERY BACKUP
F1	1	LED STRIP - 4 FT	SURFACE	120 V	36 W	TLS	GC	LITHONIA	CSS-L48-4000LM-MVOL T-40K-80CRI	INTEGRAL LED	CHAIN HANG FIXTURE AT 9" ABOVE FINISHED FLOOR
F2	9	AREA POLE LIGHT	POLE	120 V	104 W	LL	GC	US ARCHITECTURAL	LCNP1-PM-CPA-PA-III-4 8LED-700MA-40K-NUV-1-RAL8019T	INTEGRAL LED	POLE MOUNTED LED AREA LIGHT. PROVIDE WITH SQUARE ALUMINUM POLE #5NTA-206-188-PT27-RAL8019T AND PENDANT MOUNTING ARM #XAO-PM-1-RAL8019T
H1	8	VAPOR PROOF HOOD LIGHT	SURFACE	120 V	15 W	HS/TLS	HS	FURNISHED W/ HOOD	FURNISHED W/ HOOD	(1) TCP I16A19N1527K	INSTALL LAMP FURNISHED SEPARATELY BY LIGHTING SUPPLIER
J4	2	DECORATIVE PENDANT	PENDANT	120 V	9 W	TLS	GC	BARNLIGHT	BLE-C-CPT10-ASH-100-5 BK-100-CAW	GREEN CREATIVE 9A19DIM/927/GU24/R	WITH BLACK LAMP SHADE, BLACK CORD, AND OAK LAMPHOLDER
P5	3	PENDANT	PENDANT	120 V	5 W	TLS	GC	HI-LITE MFG	H-LC-91/CB12-91/20W LBL	TCP FG25D4027CCQ	ADJUST CORD LENGTH FOR MOUNTING HEIGHT CALLED FOR IN ARCHITECTURAL DRAWINGS
P6	1	DECORATIVE DINING ROOM PENDANT	PENDANT	120 V	30 W	TLS	GC	BARNLIGHT	BLE-C-JGT-133-35630-3	INTEGRAL LED	HARDWIRED SET OF (3) HEADS WITH UNIVERSAL CANOPY AND STANDARD BLACK CORDS
S1	1	DRIVE-UP PICK-UP WINDOW CHIME/STROBE	WALL	16 V	0 W	TLS	GC	FEDERAL SIGNAL	SLM500B W/ SLMBW-012-024	INTEGRAL	SET SWITCH A TO "CHIME 1 SINGLE" (11011) AND SWITCH B TO "CHIME 2 SINGLE" (00111)
T1	15	TRACK HEAD	TRACK	120 V	10 W	TLS	GC	JUNO	R60SL 30K 90CRI PDIM WFL BL	INTEGRAL LED	BLACK CYLINDER TRACK HEAD W/ UNIVERSAL 120V TRAC ADAPTER AND WIDE FLOOD BEAM
T-6	4	TRACK (6 FT)	SURFACE	120 V	0 W	TLS	GC	JUNO	T 6FT BL	N/A	SINGLE CIRCUIT, BLACK FINISH. FURNISH WITH CONNECTORS TO ACHIEVE ARRANGEMENT SHOWN ON PLANS. TRIM AS REQUIRED FOR LENGTHS SHOWN.
T-8	1	TRACK (8 FT)	SURFACE	120 V	0 W	TLS	GC	JUNO	T 8FT BL	N/A	SINGLE CIRCUIT, BLACK FINISH. FURNISH WITH CONNECTORS TO ACHIEVE ARRANGEMENT SHOWN ON PLANS. TRIM AS REQUIRED FOR LENGTHS SHOWN.
TCL-0.5	1	TRACK CURRENT LIMITER (60W)	SURFACE	120 V	0 W	TLS	GC	JUNO	TCLFM11 8L W/ TCLCB 0.5A BLCK	N/A	BLACK CURRENT LIMITING END FEED WITH CIRCUIT BREAKER
TCL-2	1	TRACK CURRENT LIMITER (240W)	SURFACE	120 V	0 W	TLS	GC	JUNO	TCLFM11 8L W/ TCLCB 2A BLCK	N/A	BLACK CURRENT LIMITING END FEED WITH CIRCUIT BREAKER
W1	4	WIC LED LIGHT	SURFACE	120 V	29 W	WCS	GC	FURNISHED W/ WIC	FURNISHED W/ WIC	INTEGRAL LED	WET-RATED COOLER FIXTURE
X6	3	EXTERIOR LED WALL MOUNTED LIGHT	SURFACE	120 V	33 W	LL	GC	US ARCHITECTURAL	LCNP12-CPA/XCNA-UP-PLD-III-20LED-525MA-40K-UNV-RAL8019T	INTEGRAL LED	WALL MOUNTED LED DECORATIVE AREA LIGHT.
X9	2	EXTERIOR LED CHANNEL LIGHT	SURFACE	120 V		LL	GC	PARADIGM LED	AMC-2410-S W/ OPAL LENS AND END CAPS	FLEXSR-45-30-67-24	FURNISHED W/ REMOTE-MOUNTED NEMA 3R LED DRIVER. SEE PLAN FOR LENGTHS.

LIGHTING FIXTURE SCHEDULE NOTES


A. SEE THE ARCHITECTURAL REFLECTED CEILING PLAN FOR EXACT LIGHT LOCATIONS.
B. SEE THE ARCHITECTURAL LIGHTING DETAILS FOR FIXTURE CONSTRUCTION DETAILS.

ELECTRICAL LIGHTING PLAN NOTES

1. INSTALL WALL-MOUNTED LIGHTING OVERRIDE SWITCH AND CONNECT TO LCP AS SHOWN IN DETAIL 6/E710
2. FOR UNCIRCUITED LIGHT FIXTURES, CONNECT TO RELAY CIRCUIT INDICATED NEXT TO THE FIXTURE TAG THROUGH THE LIGHTING CONTROL PANEL (LCP) UNLESS NOTED OTHERWISE.
3. WALL MOUNT THE EMERGENCY LIGHT FIXTURE AT 6" BELOW THE CEILING UNLESS NOTED OTHERWISE
4. VERIFY MOUNTING HEIGHT OF EXIT SIGN PRIOR TO ROUGH IN. EXIT SIGN MUST BE VISIBLE FROM AREA SERVED AFTER BUILDING SYSTEMS HAVE BEEN INSTALLED. SEE ARCHITECTURAL ELEVATIONS FOR FURTHER INFORMATION.
5. INSTALL LED DRIVERS FURNISHED WITH THE X9 LED STRIP LIGHTS ON WALL 6" ABOVE THE CEILING IN AN ACCESSIBLE LOCATION. PROVIDE LOW VOLTAGE WIRING FROM LED DRIVER TO THE X9 LIGHT FIXTURES AS SHOWN.
6. INSTALL LIGHT FIXTURES FURNISHED WITH THE WALK-IN COOLER. PROVIDE UNSWITCHED CONDUCTOR FROM LIGHTING CIRCUIT TO WALK-IN COOLER LIGHTING J-BOX AND FROM J-BOX TO LIGHT FIXTURES AS SHOWN. CONDUIT BETWEEN LIGHT FIXTURES SHALL BE ROUTED ON THE INTERIOR OF THE WALK-IN COOLER. SEAL INTERIOR AND EXTERIOR OF CONDUITS WHERE THEY PASS THROUGH THE WALK-IN COOLER ENVELOPE PER THE NEC.
7. NOT USED.
8. PROVIDE UNISTRUT AS SHOWN ON THE ARCHITECTURAL RCP PER THE ARCHITECTURAL UNISTRUT DETAIL, TYPICAL.
9. CONNECT EXTERIOR LIGHTING CIRCUIT TO CIRCUIT SHOWN THROUGH THE EXTERIOR LIGHTING CONTACTOR PANEL PER DETAIL 6/E710.
10. INSTALL WALL-MOUNTED OCCUPANCY SENSOR FURNISHED BY LIGHTING SUPPLIER AT 42" AFF. ADJUST OCCUPANCY SENSOR TO PROVIDE AUTOMATIC ON/AUTOMATIC OFF OPERATION WITH A FIXED TIMER OF 30 MINUTES AND WITH BOTH THE PASSIVE INFRARED AND ULTRASONIC SENSORS ENABLED.
11. NOT USED.
12. INSTALL WALL-MOUNTED DIMMERS ABOVE PANELBOARDS 6" ABOVE LAY-IN CEILING FOR CONTROL OF DINING ROOM OVERHEAD STRIP LED AND PENDANT LIGHTS. CONNECT DIMMERS TO RELAYS SHOWN THROUGH THE LIGHTING CONTROL PANEL. SET DIMMERS AT 50%.
13. CONNECT DINING ROOM (RELAY CIRCUITS R4 AND R5) OVERHEAD STRIP LED LIGHTS TO THE RELAY INDICATED THROUGH THE CORRESPONDING WALL-MOUNTED DIMMER INSTALLED ABOVE THE PANELBOARDS.
14. INSTALL LIGHTING CONTROL SYSTEM PER DETAIL 6/E710.
15. NOT USED.


ELECTRICAL LIGHTING PLAN NOTES

16. PENETRATIONS THROUGH SHEAR WALL SHALL BE LIMITED TO 10" DIAMETER (OR A GROUP OF PENETRATIONS ALL CONTAINED WITHIN 10" DIAMETER). IF LARGER PENETRATIONS OR GROUPS OF PENETRATIONS ARE REQUIRED COORDINATE WITH STRUCTURAL ENGINEER FOR APPROPRIATE BRACING. SEE STRUCTURAL DRAWINGS FOR SHEAR WALL LOCATION.
17. INSTALL CHIME/STROBE FURNISHED WITH VEHICLE DETECTION SYSTEM ON WALL 12" BELOW CEILING AND CONNECT TO VEHICLE DETECTOR SYSTEM PER THE MANUFACTURER'S INSTALLATION INSTRUCTIONS.
18. LANDLORD PROVIDED EMERGENCY LIGHT LOCATED AT BOTTOM OF CANOPY. CONCEAL LOW VOLTAGE WIRING FROM EXIT SIGN TO REMOTE EMERGENCY LIGHT.
19. LED STRIP INSTALLED UNDER CANOPY BY THE LANDLORD. MAKE POWER CONNECTION AS SHOWN.
20. EXTERIOR LED WALL MOUNTED LIGHT INSTALLED BY THE LANDLORD. MAKE POWER CONNECTION AS SHOWN.
21. LANDLORD PROVIDED EXIT SIGN. CONNECT EXIT SIGN TO CIRCUIT AS SHOWN.
22. LANDLORD PROVIDED LIGHT FIXTURES IN ROOM. CONNECT CIRCUIT WIRING FROM DELIVERY LIGHT FIXTURE TO EXISTING LANDLORD PROVIDED LIGHT FIXTURE.
23. LANDLORD PROVIDED EMERGENCY LIGHT. CONCEAL LOW VOLTAGE WIRING FROM EXIT SIGN TO REMOTE EMERGENCY LIGHT.

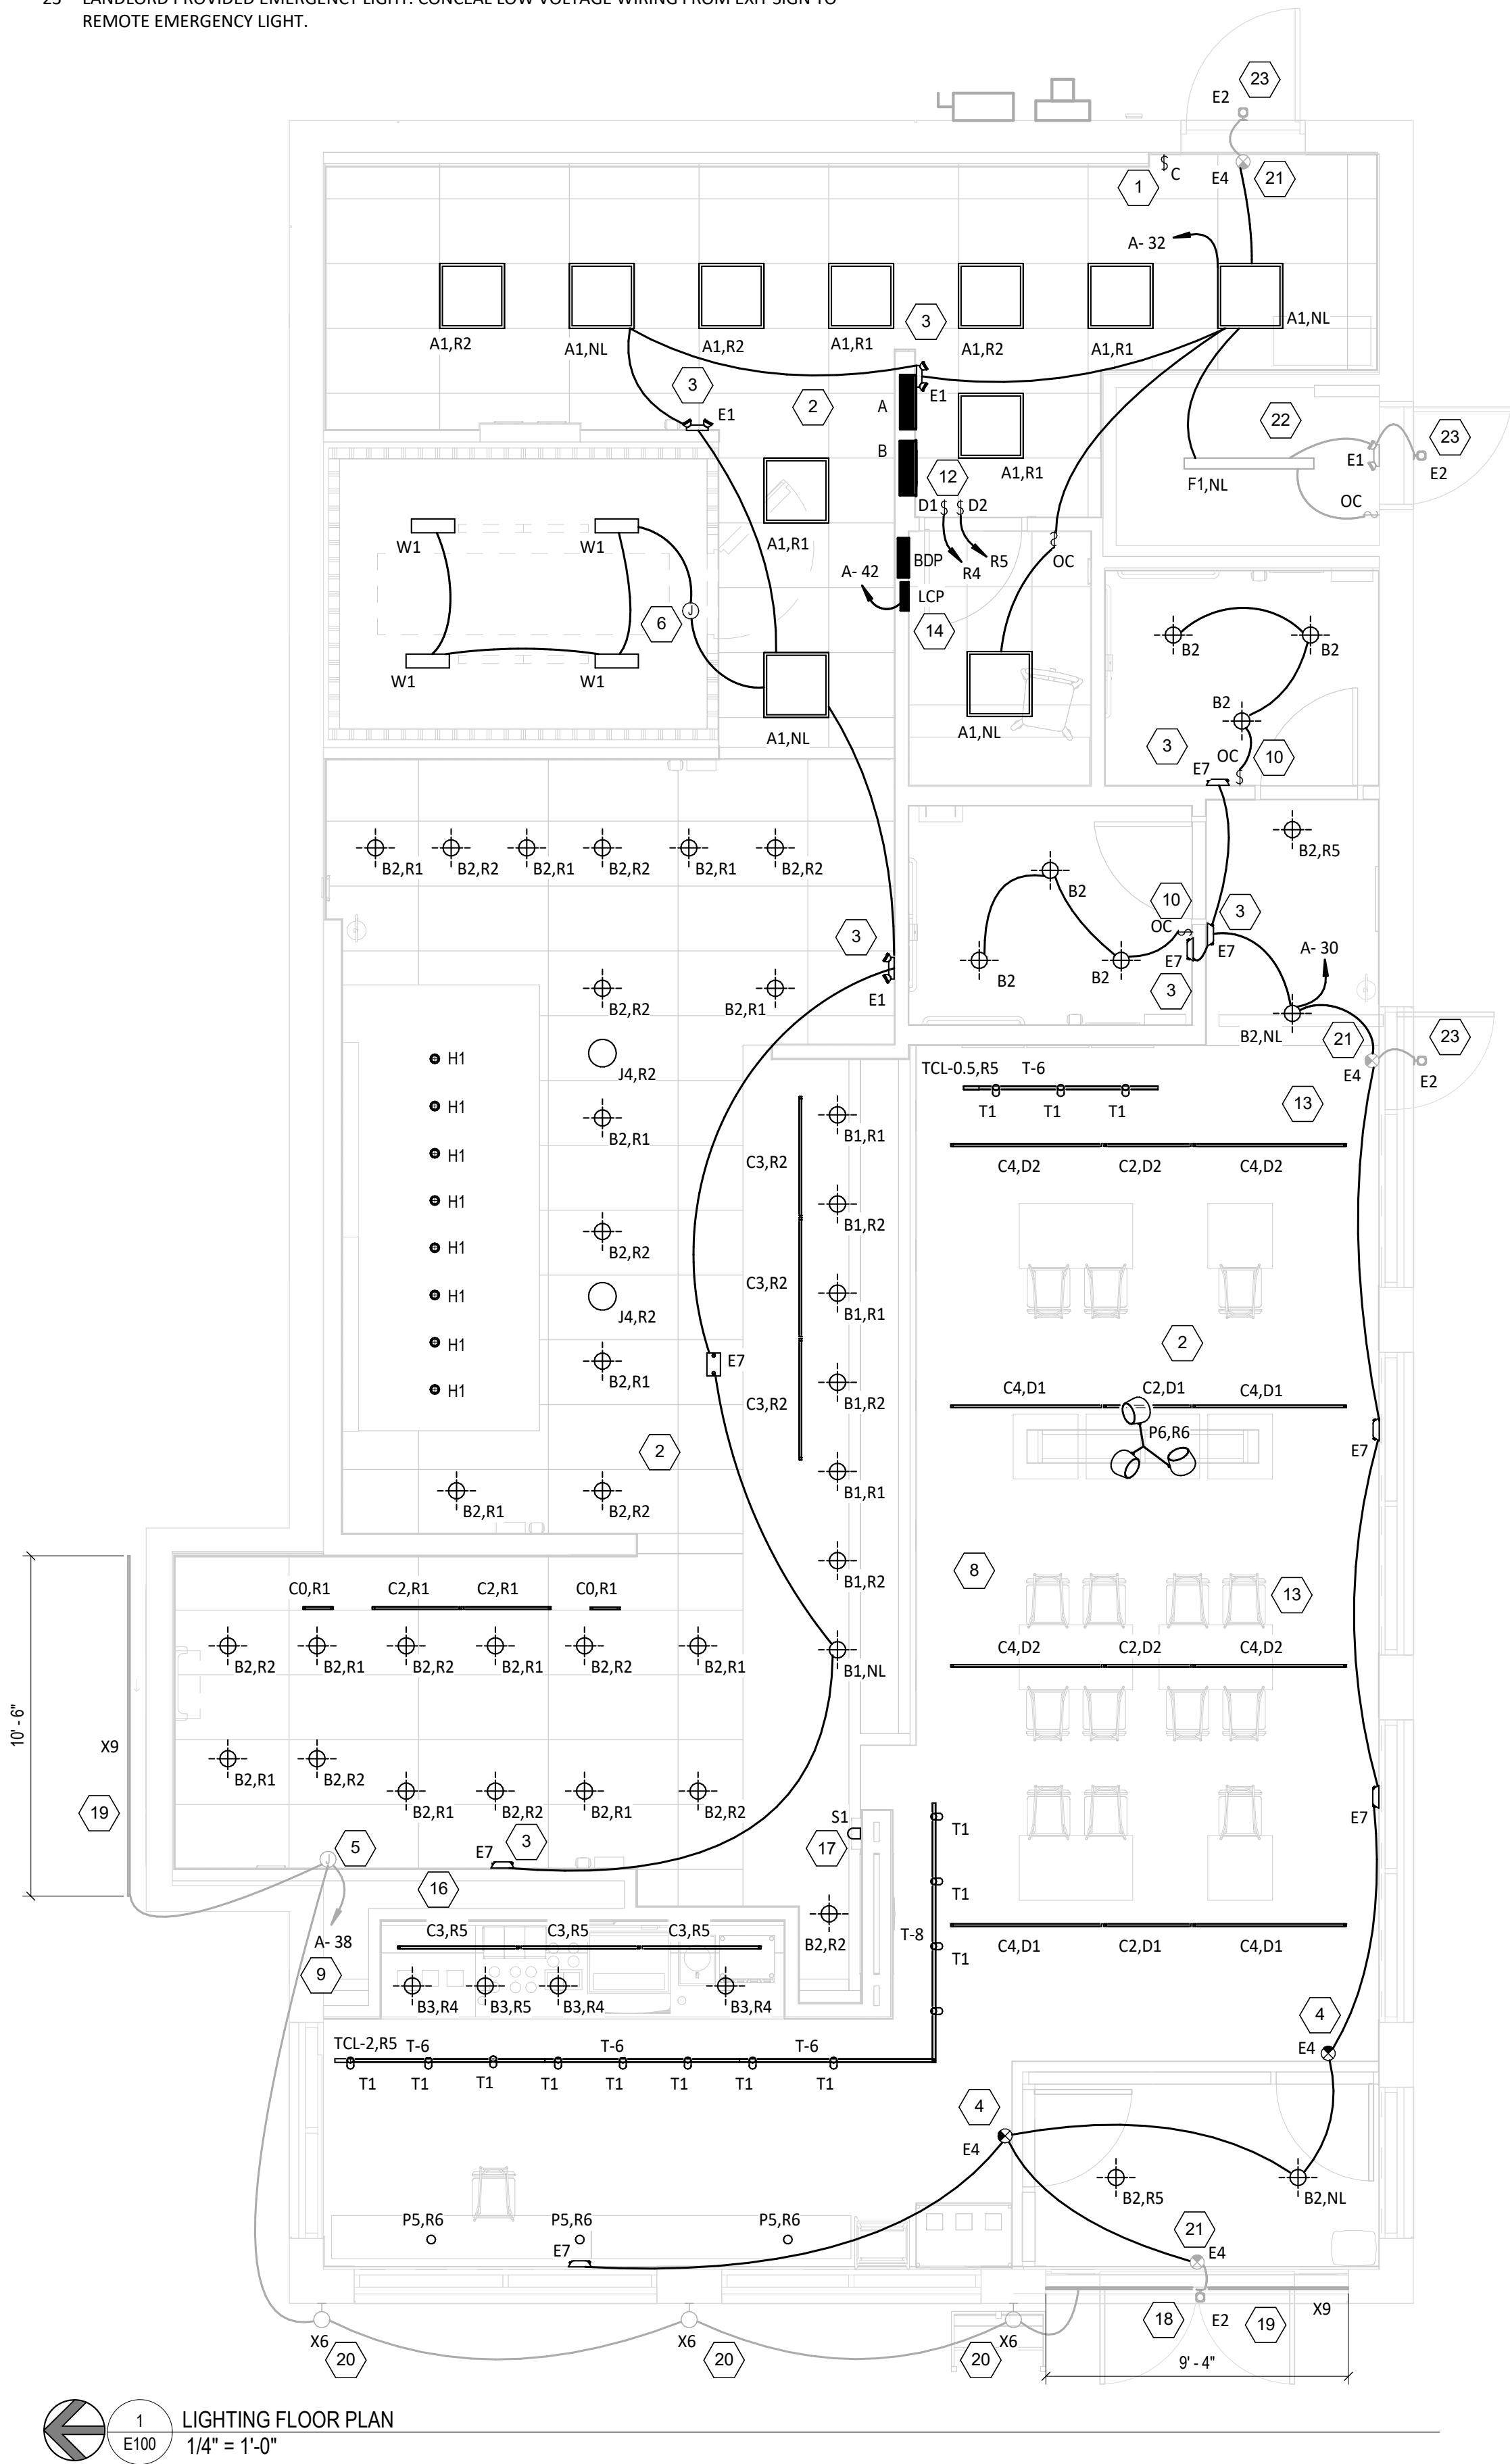

Consultant:

AYRES
MECHANICAL, ELECTRICAL,
PLUMBING (MEP)
1700 West Highway 36 - Suite 700
Roseville, Minnesota 55113
(651) 639-9606 Fax (651) 639-9618
Project No. 81-0606

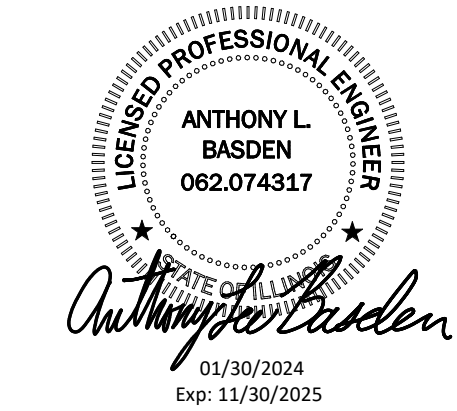

COPYRIGHT 2024
THIS DRAWING IS AN INSTRUMENT OF SERVICE AND AS SUCH REMAINS THE PROPERTY OF CHIPOTLE MEXICAN GRILL, INC. PERMISSION FOR USE OF THIS DOCUMENT IS LIMITED AND CAN BE EXTENDED ONLY BY WRITTEN AGREEMENT WITH CHIPOTLE MEXICAN GRILL, INC.



CHIPOTLE MEXICAN GRILL, INC.
PO BOX 182566
COLUMBUS, OH 43218-2566
(614) 318-2400
www.chipotle.com

STORE NO.: 5037

"HUNTLEY"

12990 ROUTE 47, LOT 4B
HUNTLEY, IL 60142

Issue Record:

01/30/2024	PERMIT SUBMITTAL
03/15/2024	BID SET
05/03/2024	CONSTRUCTION SET

Revisions:

03/07/24	CITY COMMENTS
----------	---------------

Drawn: AIA
Checked: ALB

Project No.

2023-0175

Contents:

ELECTRICAL
LIGHTING PLAN

E100

FROM ROOM WINDOW RECEPTACLE. COORDINATE EXACT RECEPTACLE MOUNTING HEIGHT IN THE FIELD. LOCATION SHALL BE IN THE DRYWALL IMMEDIATELY ABOVE THE MAIN STORE-FRONT WINDOW AND AS SHOWN IN THE DINING ROOM ELECTRICAL ELEVATIONS ON SHEET E700.

ICE MACHINE ELECTRICAL TIE-IN. COORDINATE EXACT LOCATION WITH EQUIPMENT INSTALLER PRIOR TO ROUGH-IN. PROVIDE 1/2" FLANGED INLET WIRED TO THE REMOTE CONDENSER. PROVIDE 48" CORDS, ONE WITH 5-20P END AND ONE WITH 15-20R END, FROM ICE MAKER TO RECEPTACLE AND FLANGED INLET.

CONNECT RECEPTABLES SERVING EQUIPMENT BELOW THE KITCHEN HOOD TO THE CIRCUITS SHOWN THROUGH THE CONTACTOR INTEGRAL TO THE HOOD CONTROL PANEL. INTEGRAL CONTACTOR SHALL BE INTERLOCKED TO HOOD FIRE PROTECTION SYSTEM SO THAT RECEPTABLES ARE DE-ENERGIZED UPON ACTIVATION OF HOOD FIRE PROTECTION SYSTEM.

JUNCTION BOX FOR EXTERIOR SIGN LIGHTING. COORDINATE EXACT LOCATION WITH CHIPOTLE'S CONSTRUCTION MANAGER AND THE SIGN INSTALLER PRIOR TO ROUGH-IN. CONNECT TO CIRCUIT SHOWN THROUGH THE EXTERIOR LIGHTING CONTACTOR PANEL AS SHOWN IN DETAIL E6/710.

PROVIDE 4" OCTAGONAL JUNCTION BOX WITH SCREW THREADS SET AT THE 2 & 8 O'CLOCK POSITIONS FOR THE ANSUL PULL STATION. PROVIDE A 1/2" CONDUIT FROM THE J-BOX TO 6" ABOVE THE CEILING AND TERMINATE WITH A CONDUIT BUSHING. COORDINATE EXACT LOCATION WITH THE ANSUL SYSTEM INSTALLER AND THE FIRE MARSHALL PRIOR TO ROUGH-IN.

HOOD CONTROL PANEL AND ANSUL CABINET SHALL BE LOCATED WITHIN THE INTEGRAL HOOD UTILITY CABINET. PROVIDE FINAL ELECTRICAL CONNECTIONS PER THE MANUFACTURER'S INSTALLATION INSTRUCTIONS NECESSARY FOR A COMPLETE AND OPERATIONAL SYSTEM.

NOT USED.

PROVIDE AN EMPTY SINGLE GANG J-BOX FOR VOLUME CONTROLS. INSTALL THE CAT5 VOLUME CONTROL WIRE FURNISHED BY THE TENANT FROM THE J-BOX TO THE AMPLIFIER IN THE OFFICE WITH 3 FEET OF SLACK AT EACH END.

COORDINATE DATA/POWER RECEPTACLE MOUNTING REQUIREMENTS WITH THE CASE WORK INSTALLER PRIOR TO ROUGH-IN.

PROVIDE ROUGH-INS FOR LAUNCHPORT AS NOTED. LAUNCHPORT WILL BE FURNISHED AND INSTALLED BY CHIPOTLE WITH THE WALLSTATION AT 62" AFF. PROVIDE A 4" X 2-1/8" DEEP OCTAGON J-BOX WITH 1-1/2" EXTENSION RING AT 62" AFF FOR THE WALLSTATION INSTALLATION WITH A 1" CONDUIT WITH PULL STRING FROM THE J-BOX TO ABOVE THE OFFICE CEILING.

PROVIDE (2) EMPTY 2" CONDUIT WITH PULL STRING FROM THE BASE BUILDING'S TELEPHONE AND DATA SERVICE ENTRANCE LOCATION TO THE SPACE ABOVE THE OFFICE CEILING. TERMINATE WITH CONDUIT BUSHING.

PROVIDE A SUITABLE LENGTH OF LIQUID-TIGHT CONDUIT TO THE EXHAUST FAN EF-1 TO ALLOW THE EXHAUST FAN TO HINGE COMPLETELY OPEN WHEN THE VIROGUARD SYSTEM IS INSTALLED.

AFTER THE FAX LINE, POS, AND OFFICE EQUIPMENT IS INSTALLED PROVIDE CHILDPROOF RECEPTACLE COVERS ON UNUSED IG RECEPTABLES AT THE FAX LINE, POS, AND OFFICE.

PROVIDE ONE PHASE, ONE NEUTRAL, AND ONE GROUND CONDUCTOR FROM THE ICE MAKER TO THE REMOTE CONDENSING UNIT.

UNIT SHALL HAVE AN INTEGRAL NON-FUSED DISCONNECT SWITCH.

INSTALL UNIT-MOUNTED WEATHERPROOF GFCI RECEPTACLE. PROVIDE CONNECTION TO CIRCUIT SHOWN.

INSTALL THE BYPASS DISTRIBUTION PANEL (BDP) FURNISHED BY THE TENANT. INSTALL PER THE MANUFACTURER'S INSTALLATION INSTRUCTIONS AND DETAIL 3/E710.

ROUGH-INS TO SERVE LINE AND POS EQUIPMENT ARE UNDERGROUND. COORDINATE ROUGH-IN REQUIREMENTS AND LOCATIONS WITH EQUIPMENT MANUFACTURER PRIOR TO ROUGH-IN.

ROOFTOP UNIT SHALL HAVE AN INTEGRAL UNIT-MOUNTED GFCI RECEPTACLE. PROVIDE CONNECTION TO CIRCUIT SHOWN.

ICE MAKER RECEPTABLES SHALL BE CONCEALED BEHIND THE ICE MAKER. COORDINATE LOCATION WITH ACTUAL WIDTH OF ICE MAKER.

PROVIDE VERTICAL METAL DIE CAST WEATHERPROOF WHILE IN USE OUTLET COVER ON RECEPTABLES AT COOK LINE. COVER SHALL BE INTERMATIC WP1010MXD FOR SINGLE GANG BOXES AND WP1030MXD FOR DOUBLE GANG BOXES. NO SUBSTITUTIONS SHALL BE ACCEPTED.

LABEL BATTERY-PROTECTED RECEPTABLES "BATTERY-PROTECTED; DISCONNECT AT PANEL BDP".

LABEL MAIN DISCONNECT SWITCH AND PANEL A "WARNING: BATTERY-PROTECTED RECEPTABLES IN USE. DISCONNECT AT PANEL BDP."

PROVIDE A NEMA 5-20P FLANGED INLET (LEVITON MODEL #15378-C) AND A SINGLE NEMA 5-20R RECEPTACLE IN OFFICE FOR CONNECTION TO A CENTRAL UPS SYSTEM. CONNECT THE FLANGED INLET AND THE SINGLE RECEPTACLE TO THE TERMINAL BLOCK IN THE BDP PER THE MANUFACTURER'S INSTRUCTIONS. PROVIDE FINAL CONNECTION FROM FLANGED INLET TO THE OUTPUT OF THE UPS USING A 2" LONG 20A EXTENSION CORD. PLUG THE UPS INTO THE SINGLE RECEPTACLE.

CONNECT RESTROOM EXHAUST FAN TO CIRCUIT SHOWN THROUGH THE LIGHTING CONTROL PANEL (LCP).

INSTALL 16/2 SPEAKER WIRE FURNISHED BY OWNER. INSTALL SPEAKER WIRE BETWEEN SPEAKERS IN THE DINING ROOM AS SHOWN AND TO THE AMPLIFIER IN THE OFFICE WITH 3 FEET OF SLACK AT EACH END. THERE SHALL BE TWO SPEAKER WIRE HOMERUNS WITH THREE SPEAKERS ON EACH HOMERUN. SEE ARCHITECTURAL PLANS FOR SPEAKER LOCATIONS. ADJUST EACH SPEAKER 70V TAP SETTING TO BE 15 WATTS.

PROVIDE POWER CONNECTIONS TO ISLAND PREP TABLE PER DETAIL 2/E710. PROVIDE GFCI DUPLEX RECEPTABLES IN TWO J-BOXES INTEGRAL TO PREP TABLE FOR HOT HOLDING CABINET AND GENERAL RECEPTACLE.

PROVIDE GFCI RECEPTACLE AND J-BOX AND INSTALL CO2 ALARM FURNISHED BY CO2AS AS SHOWN IN DETAIL 4/E710.

PROVIDE J-BOX AND INSTALL CO2 ALARM REMOTE DISPLAY UNIT FURNISHED BY CO2AS AS SHOWN IN DETAIL 4/E710.

INSTALL WALK-IN-COOLER EXTERNAL READOUT THERMOMETER REMOTE PROBE ON WALL OPPOSITE FROM DOOR AS SHOWN.
ROUTE TEMPERATURE PROBE WIRE ABOVE WALK-IN COOLER CEILING PANELS, SEAL PENETRATIONS THROUGH THE CEILING
PANELS, AND SECURE VERTICAL PROBE WIRE TIGHT TO WALLS. NO EXCESS PROBE WIRE SHALL BE WITHIN THE WALK-IN COOLER.

31 PROVIDE RECEPTACLE FOR RESTROOM HAND SINK FAUCET AS SHOWN IN DETAIL 14/P700.

32 PROVIDE 4" SQUARE RECESSED J-BOX ON EXTERIOR WALL FOR MOUNTING OF EXTERIOR CAMERA. SEE ARCHITECTURAL
ELEVATION FOR EXACT HEIGHT AND LOCATION. PROVIDE 3/4" CONDUIT WITH PULSTRUNG FROM J-BOX TO ABOVE LAY-IN
CEILING AREA IN KITCHEN.

33 PROVIDE 1" CONDUITS FROM LOW-VOLTAGE J-BOXES AT POS COUNTER CONCEALED WITHIN THE SERVE LINE WIRING CHASE TO
THE WALL, THEN CONCEALED WITHIN THE WALL AND ABOVE THE CEILING TO ABOVE THE OFFICE CEILING.

35 INSTALL VEHICLE DETECTOR SYSTEM FURNISHED BY TLS SURFACE-MOUNTED ON WALL 12" BELOW CEILING AND CONNECT TO
STROBE/CHIME AND DETECTOR LOOP PER THE MANUFACTURER'S INSTALLATION INSTRUCTIONS. MAKE FINAL ADJUSTMENTS TO
LOOP SENSITIVITY PER THE MANUFACTURER'S INSTRUCTIONS. ONCE ALL COMPONENTS ARE INSTALLED AND OPERATIONAL THE
CHIME/STROBE LIGHT SHOULD STAY ILLUMINATED AND THERE SHOULD BE A SINGLE CHIME WHEN A VEHICLE DRIVES OVER OR
STOPS ON LOOP.

36 SEAL INTERIOR AND EXTERIOR OF CONDUITS THAT PASS THROUGH THE WALK-IN COOLER ENVELOPE PER THE NEC.

37 PROVIDE ISLAND PREP TABLE FOOD WARMER RECEPTACLE WITH GROUND PIN TOWARDS THE BOTTOM OF THE RECEPTACLE.

38 INSTALL TRANSFORMER FURNISHED BY TUV WITH THE REME HALO AIR PURIFIER IN THE JUNCTION BOX ON THE EXTERIOR OF THE
RTU PER DETAIL 6/M700. CONNECT LINE SIDE OF THE TRANSFORMER TO THE RTU SERVICE RECEPTACLE CIRCUIT SO THAT REME
HALO RUNS CONTINUOUSLY. CONNECT THE LOW VOLTAGE SIDE OF THE TRANSFORMER TO THE REME HALO USING THE
INCLUDED BARREL PLUG.

39 PROVIDE (2) 10"x10"x4" JUNCTION BOXES (J-BOX #1/J-BOX #2) ON THE WALL ABOVE PANELBOARDS 6" BELOW THE LAY-IN
CEILING AND MOUNTED ADJACENT TO EACH. PROVIDE CONDUITS AND WIRING SHOWN IN DETAIL 8/710. TEMS SHALL PROVIDE
GRIDPOINT 3 PHASE METER AND TRANSFORMER WITHIN J-BOX #1 AND GRIDPOINT IOM/HUB WITHIN J-BOX #2. SEE GRIDPOINT
INSTALLATION SHEET FOR DETAILS.

40 PROVIDE HORIZONTAL SINGLE-GANG J-BOX BELOW FUTURE GRIDPOINT CONTROLLER LOCATION. PROVIDE CONDUITS AND
WIRING AS SHOWN IN DETAIL 8/710.

41 INSTALL WIRED DOOR BUZZER AT 96" AFF. SEE ARCHITECTURAL DOOR EQUIPMENT FOR EQUIPMENT INFORMATION. CONNECT
TO CIRCUIT SHOWN THROUGH THE TRANSFORMER FURNISHED WITH THE DOOR BUZZER. PROVIDE WIRING TO A BUTTON
ADJACENT TO THE SERVICE DOOR AND CONNECT PER THE MANUFACTURER'S INSTALLATION INSTRUCTIONS.

42 CONNECT BATHROOM SANITIZER TO CIRCUIT SHOWN SO THAT IT IS ENERGIZED AT ALL TIMES.

43 PROVIDE POWER AND LOW VOLTAGE CONNECTIONS TO DISH SANITIZING MACHINE PER DETAIL 7/710. CONNECT THE
DETERGENT DISPENSER TO THE DISH MACHINE USING THE INCLUDED WIRING HARNESS PER THE MANUFACTURER'S
INSTALLATION INSTRUCTIONS.

44 PROVIDE RECEPTACLE FOR 2-DOOR AND 1-DOOR REFRIGERATORS WITH GROUND PINS TOWARDS THE BOTTOM OF THE
RECEPTACLE.

45 PROVIDE CORD AND NEMA 5-20P PLUG FROM UTENSIL COUNTER ICE MAKER, THROUGH UTENSIL COUNTER, TO ICE MAKER
RECEPTACLE.

46 LABEL UTENSIL COUNTER RECEPTACLES "TRACTOR BEVERAGE", "ICE MAKER/IMSB", AND "SODA LABELING".

47 LABEL RECEPTACLE "UV INSECT TRAP".

48 PROVIDE POWER CONNECTIONS TO ISLAND PREP TABLE PER DETAIL 2/710. PROVIDE GFCI DUPLEX RECEPTACLE IN THE J-BOX
INTEGRAL TO PREP TABLE FOR UNDERCOUNTER REFRIGERATOR. PROVIDE FINAL CONNECTION TO CARVING STATION HEATER.

49 IF NEUTRAL CONDUCTOR IS NOT NEEDED FOR SERVE LINE HOT FOOD SERVICE TERMINATE NEUTRAL IN JUNCTION BOX.

50 PROVIDE A TWO-CONDUCTOR LOW VOLTAGE WIRE IN 3/4" C. AND (4) #12, #12 N, #12 G. IN 1" C. FROM MAU-1 TO THE HOOD
CONTROL PANEL PER THE MANUFACTURER'S INSTALLATION INSTRUCTIONS.

 

51 PROVIDE SINGLE-GANG J-BOX FOR DATA JACK AS SHOWN FOR KRONOS TIME CLOCK

52 PROVIDE 3" CONDUIT (EMT, IMC, OR RMC) THROUGH ROOF. TERMINATE WITH WEATHERHEAD 60" ABOVE ROOF FOR FUTURE
CELL BOOSTER WITH ONE (1) 90 DEGREE ELBOW AND ONE (1) 45 DEGREE PVC ATTACHMENTS - PROVIDE LOOSE FITTED.



53 PROVIDE CEILING MOUNTED ELECTRIC UNIT HEATER AS MANUFACTURED BY INEECO MODEL #931U04000V, 3KW, 208V, SINGLE
PHASE.

54 RECEPTACLE AND UNIT HEATER INSTALLED BY THE LANDLORD UNDER SEPARATE CONSTRUCTION PACKAGE. MAKE POWER
CONNECTION AS SHOWN.

55 PROVIDE POWER TO DOMESTIC CIRCULATING PUMP. VERIFY LOCATION IN FIELD .

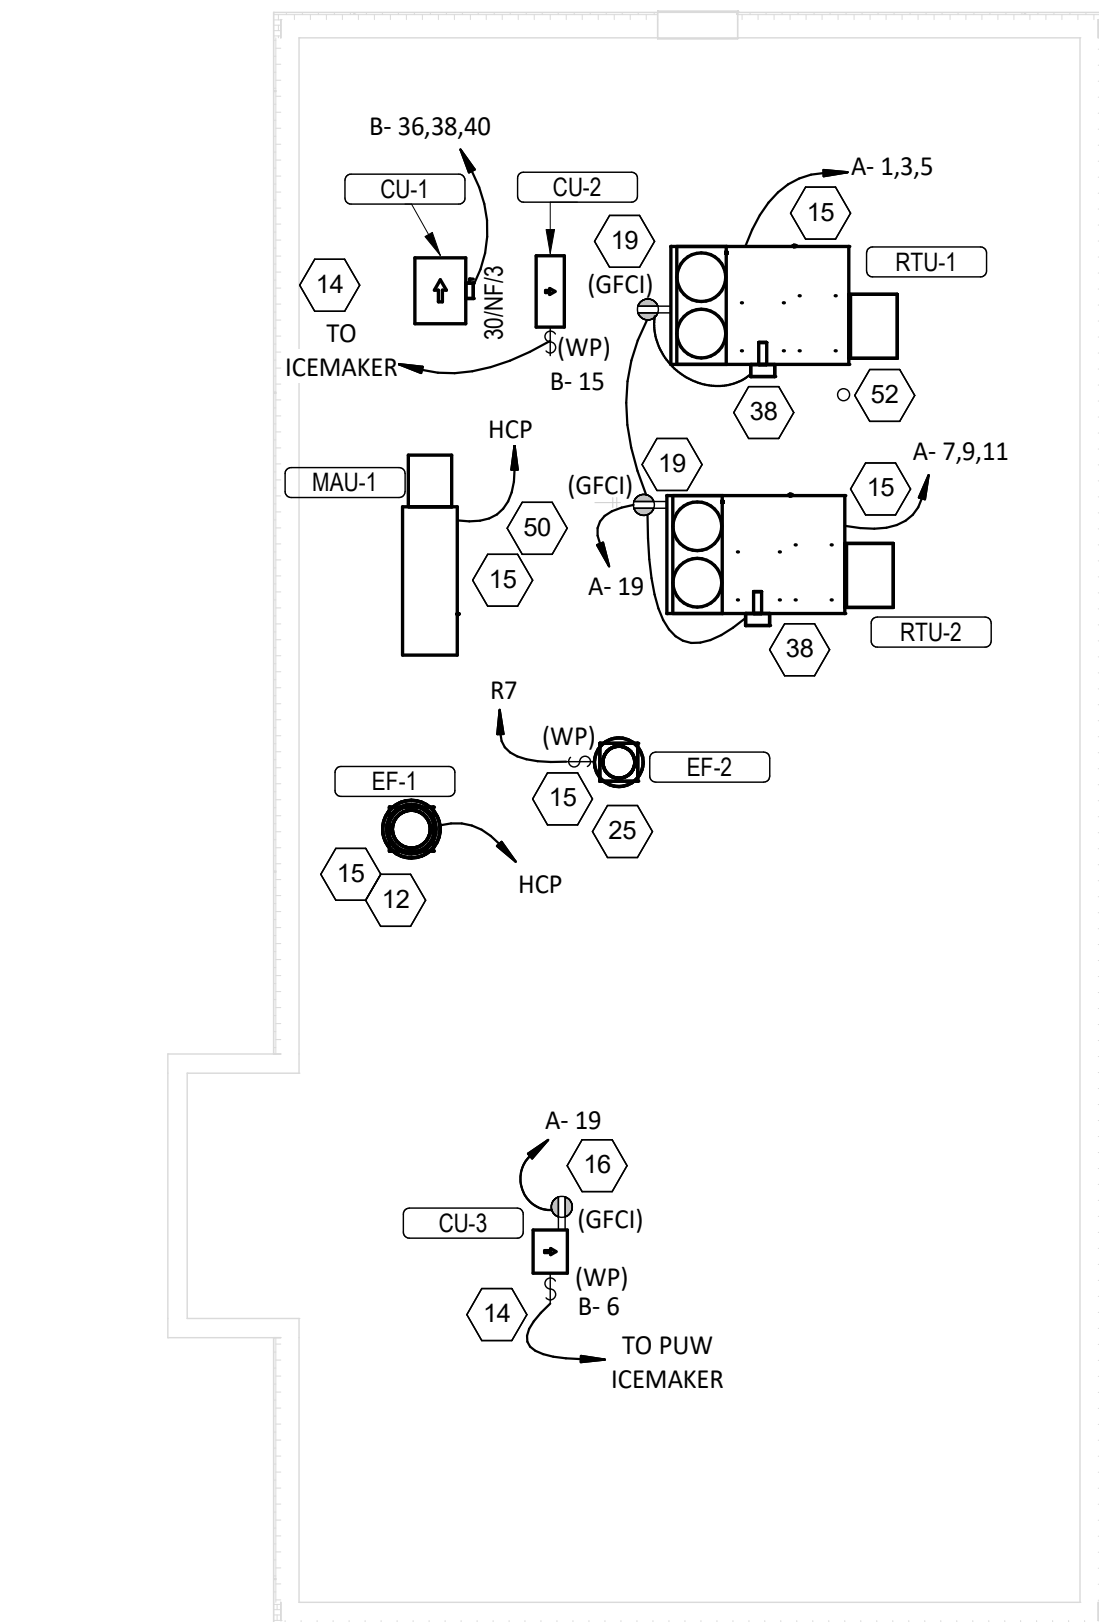

POWER ROOF PLAN
1/8" = 1'-0"

 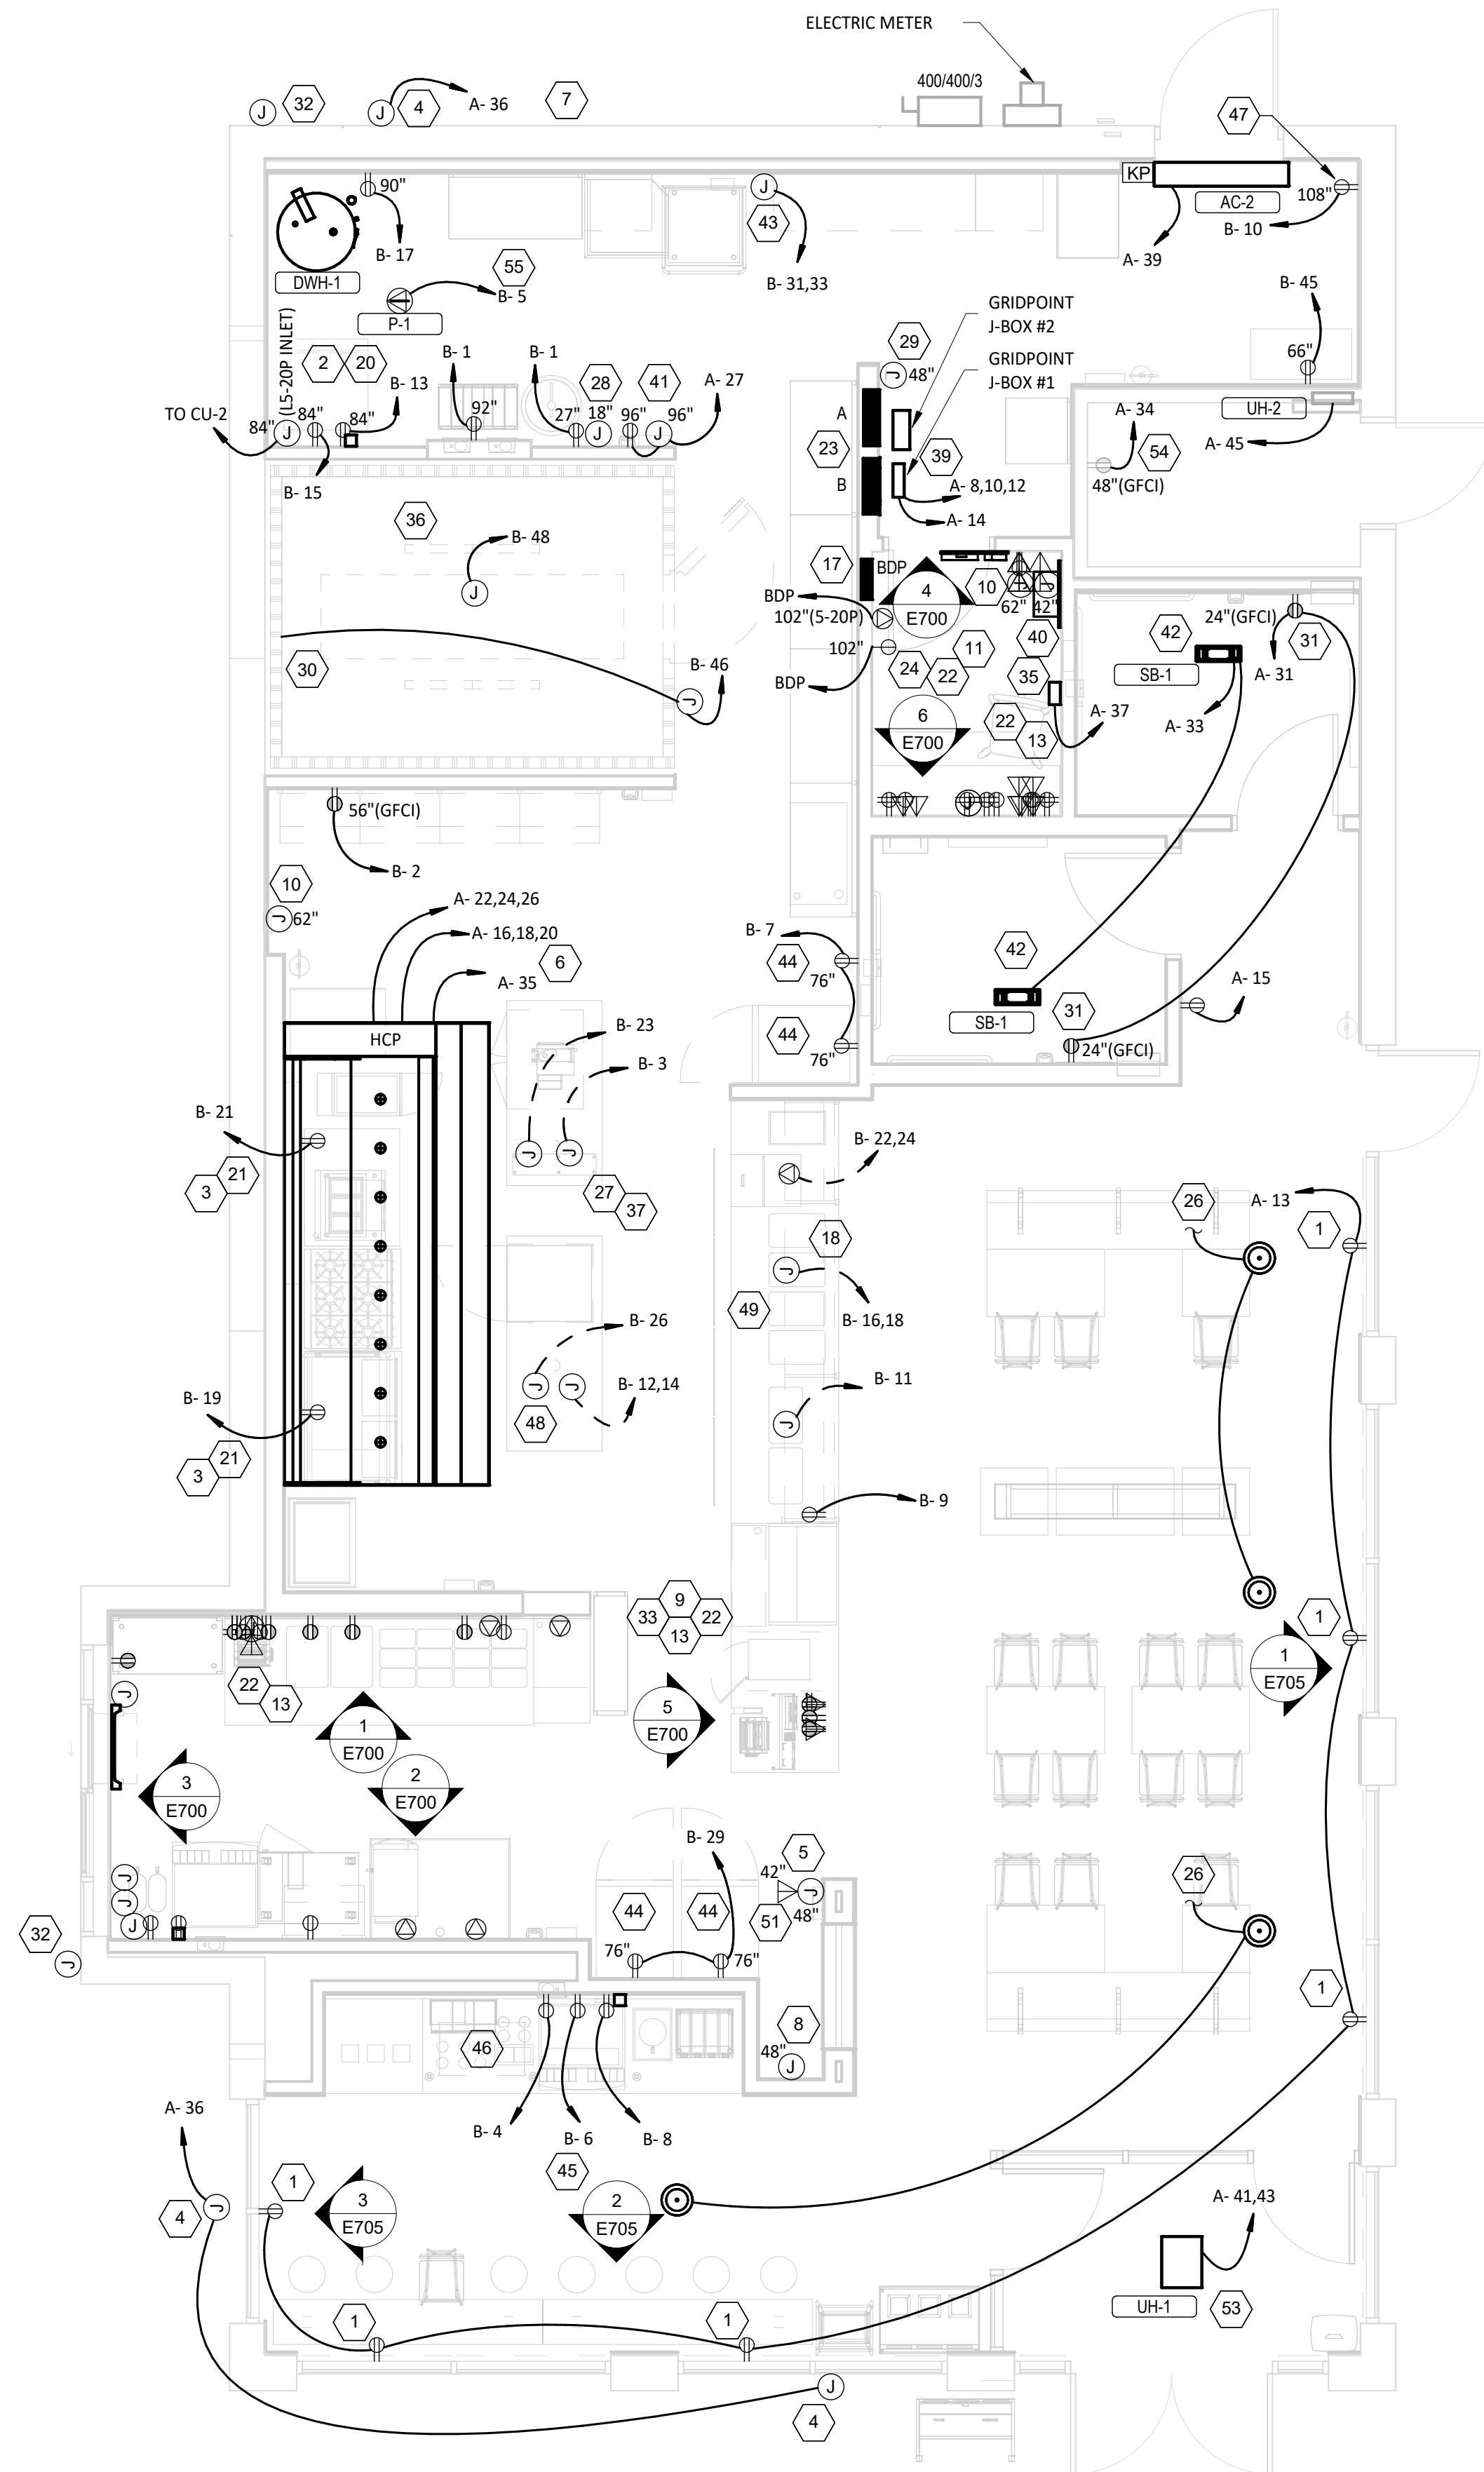

POWER FLOOR PLAN
1/4" = 1'-0"

E110


ELECTRICAL POWER PLAN NOTES

1. INSTALL VEHICLE DETECTION LOOP FURNISHED BY TLS PER THE MANUFACTURER'S INSTALLATION INSTRUCTIONS. ALIGN DETECTOR LOOP TO BE CENTERED ON THE PICK-UP WINDOW. CONDUIT FOR VEHICLE DETECTION LOOP PROVIDED BY LANDLORD.
2. CONNECT DIGITAL PICKUP SIGN TO CIRCUIT SHOWN THROUGH THE EXTERIOR LIGHTING CONTACTOR PANEL AS SHOWN IN DETAIL 6/E710. SEE DETAIL 2/THIS SHEET FOR SITE CONDUITS.
3. CONNECT MONUMENT SIGN TO CIRCUIT SHOWN THROUGH THE EXTERIOR LIGHTING CONTACTOR PANEL AS SHOWN IN DETAIL 6/E710. SEE DETAIL 2/THIS SHEET FOR SITE CONDUITS.
4. EXISTING 1" SPARE LOW VOLTAGE CONDUIT. SEE DETAIL 1/THIS SHEET FOR MORE INFORMATION.
5. EXISTING 1" SPARE LINE VOLTAGE CONDUIT. SEE DETAIL 1/THIS SHEET FOR MORE INFORMATION.
6. EXISTING INTERIOR J-BOXES AT 11'-0" AFF FOR LINE VOLTAGE AND LOW VOLTAGE SITE WIRING. SEE DETAIL 2/THIS SHEET FOR MORE INFORMATION.
7. EXISTING ELECTRIC SERVICE CONDUIT AND CONDUCTORS RUN UNDERGROUND FROM UTILITY TRANSFORMER LOCATION TO BUILDING SERVICE ENTRANCE.
8. EXISTING PADMOUNT UTILITY TRANSFORMER. COORDINATE INSTALLATION OF TRANSFORMER PAD, METER EQUIPMENT, AND SECONDARY CONDUIT AND WIRE REQUIREMENTS WITH ComED. PROVIDE TRANSFORMER ASSOCIATED SCOPE NOT PROVIDED BY ComED.
9. SITE LIGHTING LOCATIONS ARE REFERENCED ONLY - REFER TO CIVIL FOR ADDITIONAL INFORMATION. CONNECT SITE LIGHTING FIXTURES TO THE CIRCUIT SHOWN THROUGH THE EXTERIOR LIGHTING CONTACTOR PANEL AS SHOWN IN DETAIL 6/E710. SEE DETAIL 2/THIS SHEET FOR MORE INFORMATION. SIZE BRANCH CIRCUIT WIRING TO LIMIT VOLTAGE DROP TO 3 PERCENT.



GENERAL NOTES

- A. WORK AND MATERIALS SHALL BE COMPLIANT WITH THE NEC AND REQUIREMENTS OF THE AHJ.
- B. CONDUCTORS AND CONNECTIONS BELOW GRADE, EVEN WHERE WITHIN CONDUITS OR ENCLOSURES, SHALL BE SUITABLE FOR WET LOCATIONS.
- C. PROVIDE PULL STRING IN EMPTY CONDUITS.
- D. SEAL ENDS OF CONDUITS STUBBED UP ABOVE GRADE TO PROTECT FROM THE ELEMENTS.

TAG	DESCRIPTION	RESPONSIBILITY	
		DEVICE OR CONDUIT	CONNECTION OR CONDUCTORS
1	VEHICLE DETECTOR LOOP - 6"x4' WITH 4 TURNS (EMX PR-46-XX). VERIFY LENGTH OF LEAD-IN WIRE PRIOR TO ORDERING TO ALLOW WIRE TO REACH VEHICLE DETECTOR WITHOUT SPLICING. SEE SITE PLAN FOR LOCATIONS.	EXT'G	GC
2	1" CONDUIT FROM VEHICLE DETECTOR LOOP LOCATION TO LOW VOLTAGE J-BOX.	EXT'G	GC
3	1" CONDUIT FROM DIGITAL PICKUP SIGN LOCATION TO LINE VOLTAGE J-BOX. SEE SITE PLAN FOR LOCATION.	EXT'G	GC
4	NOT USED.	NA	NA
5	1" CONDUIT FROM SITE DIRECTIONAL SIGNAGE AND/OR MONUMENT SIGN LOCATION(S) TO LINE VOLTAGE J-BOX. SEE SITE PLAN FOR LOCATIONS AND NUMBER OF ROUGH-IN LOCATIONS.	EXT'G	GC
6	1" CONDUIT FROM SITE LIGHTING FIXTURE(S) TO LINE VOLTAGE J-BOX. SITE FIXTURES CAN BE DAISY-CHAINED.	EXT'G	GC
7	LINE VOLTAGE J-BOX - MINIMUM 6"x6"x4" J-BOX ON INTERIOR WALL OF BUILDING AT 11'-0" AFF. SEE SITE PLAN FOR LOCATION.	EXT'G	GC
8	LOW VOLTAGE J-BOX - MINIMUM 6"x6"x4" J-BOX ON INTERIOR WALL OF BUILDING AT 11'-0" AFF. SEE SITE PLAN FOR LOCATION.	EXT'G	GC

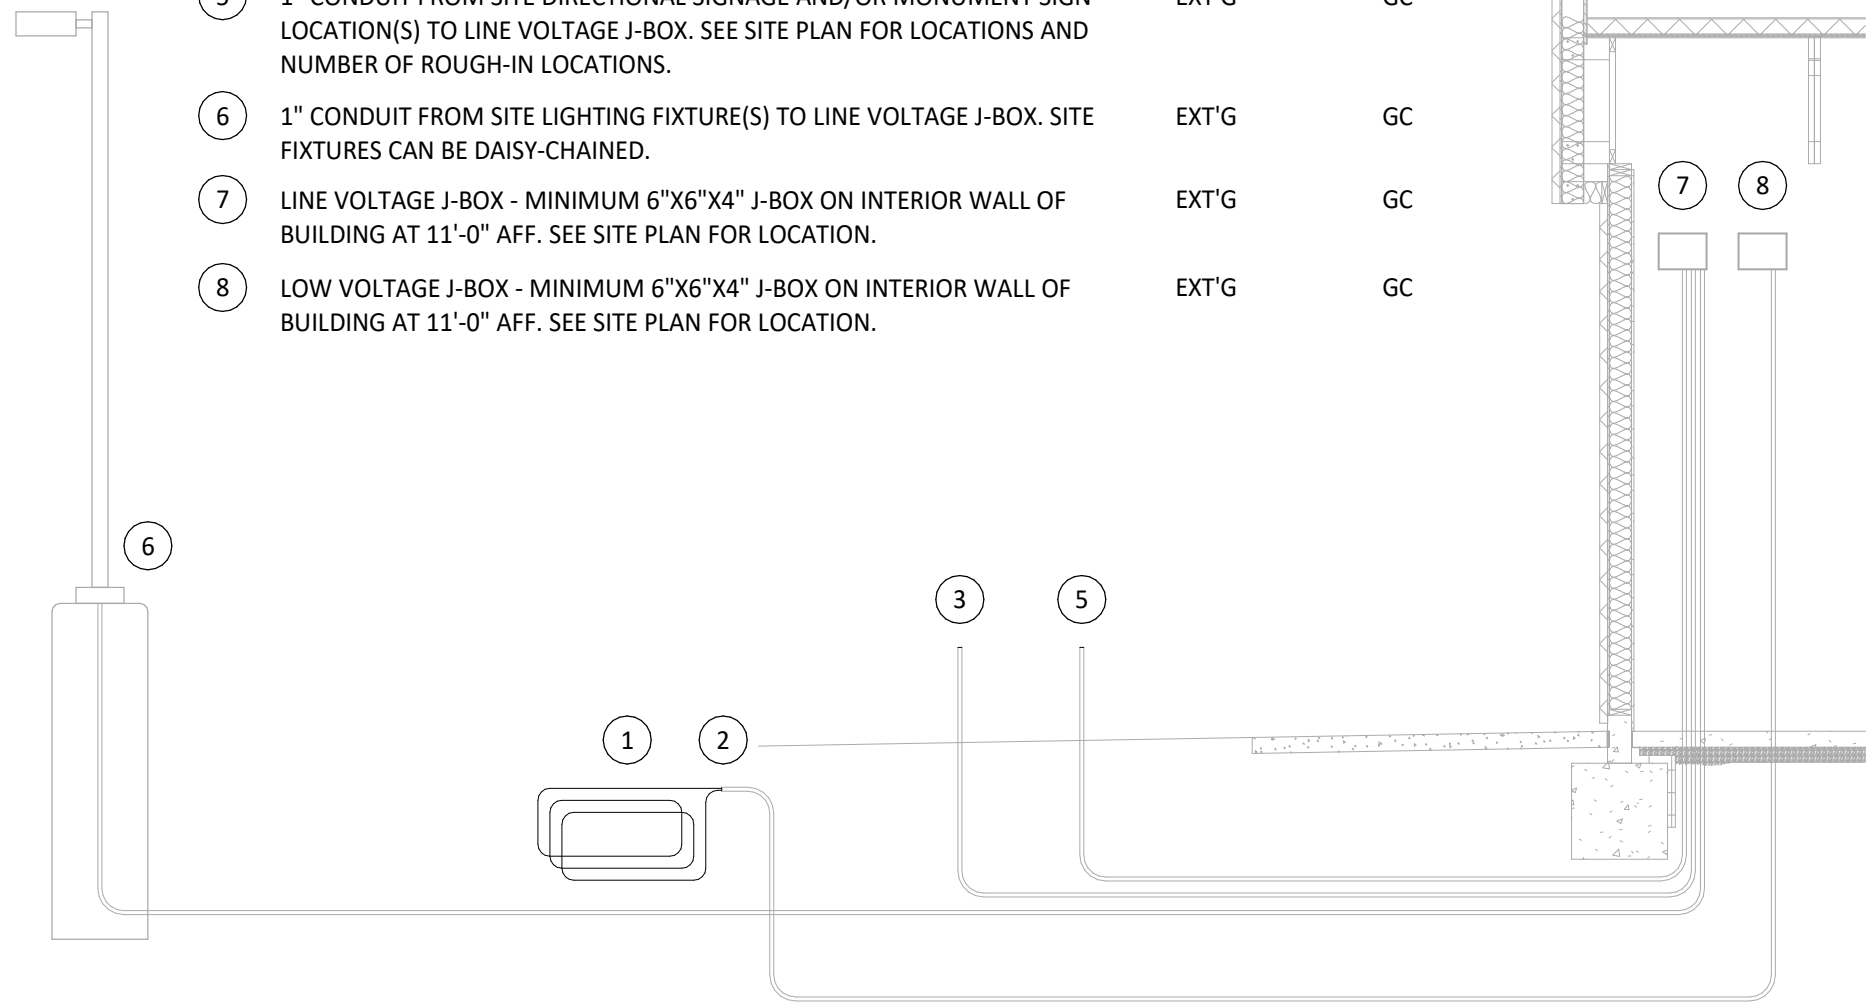


2 SITE CONDUIT DETAIL
E115 NOT TO SCALE

 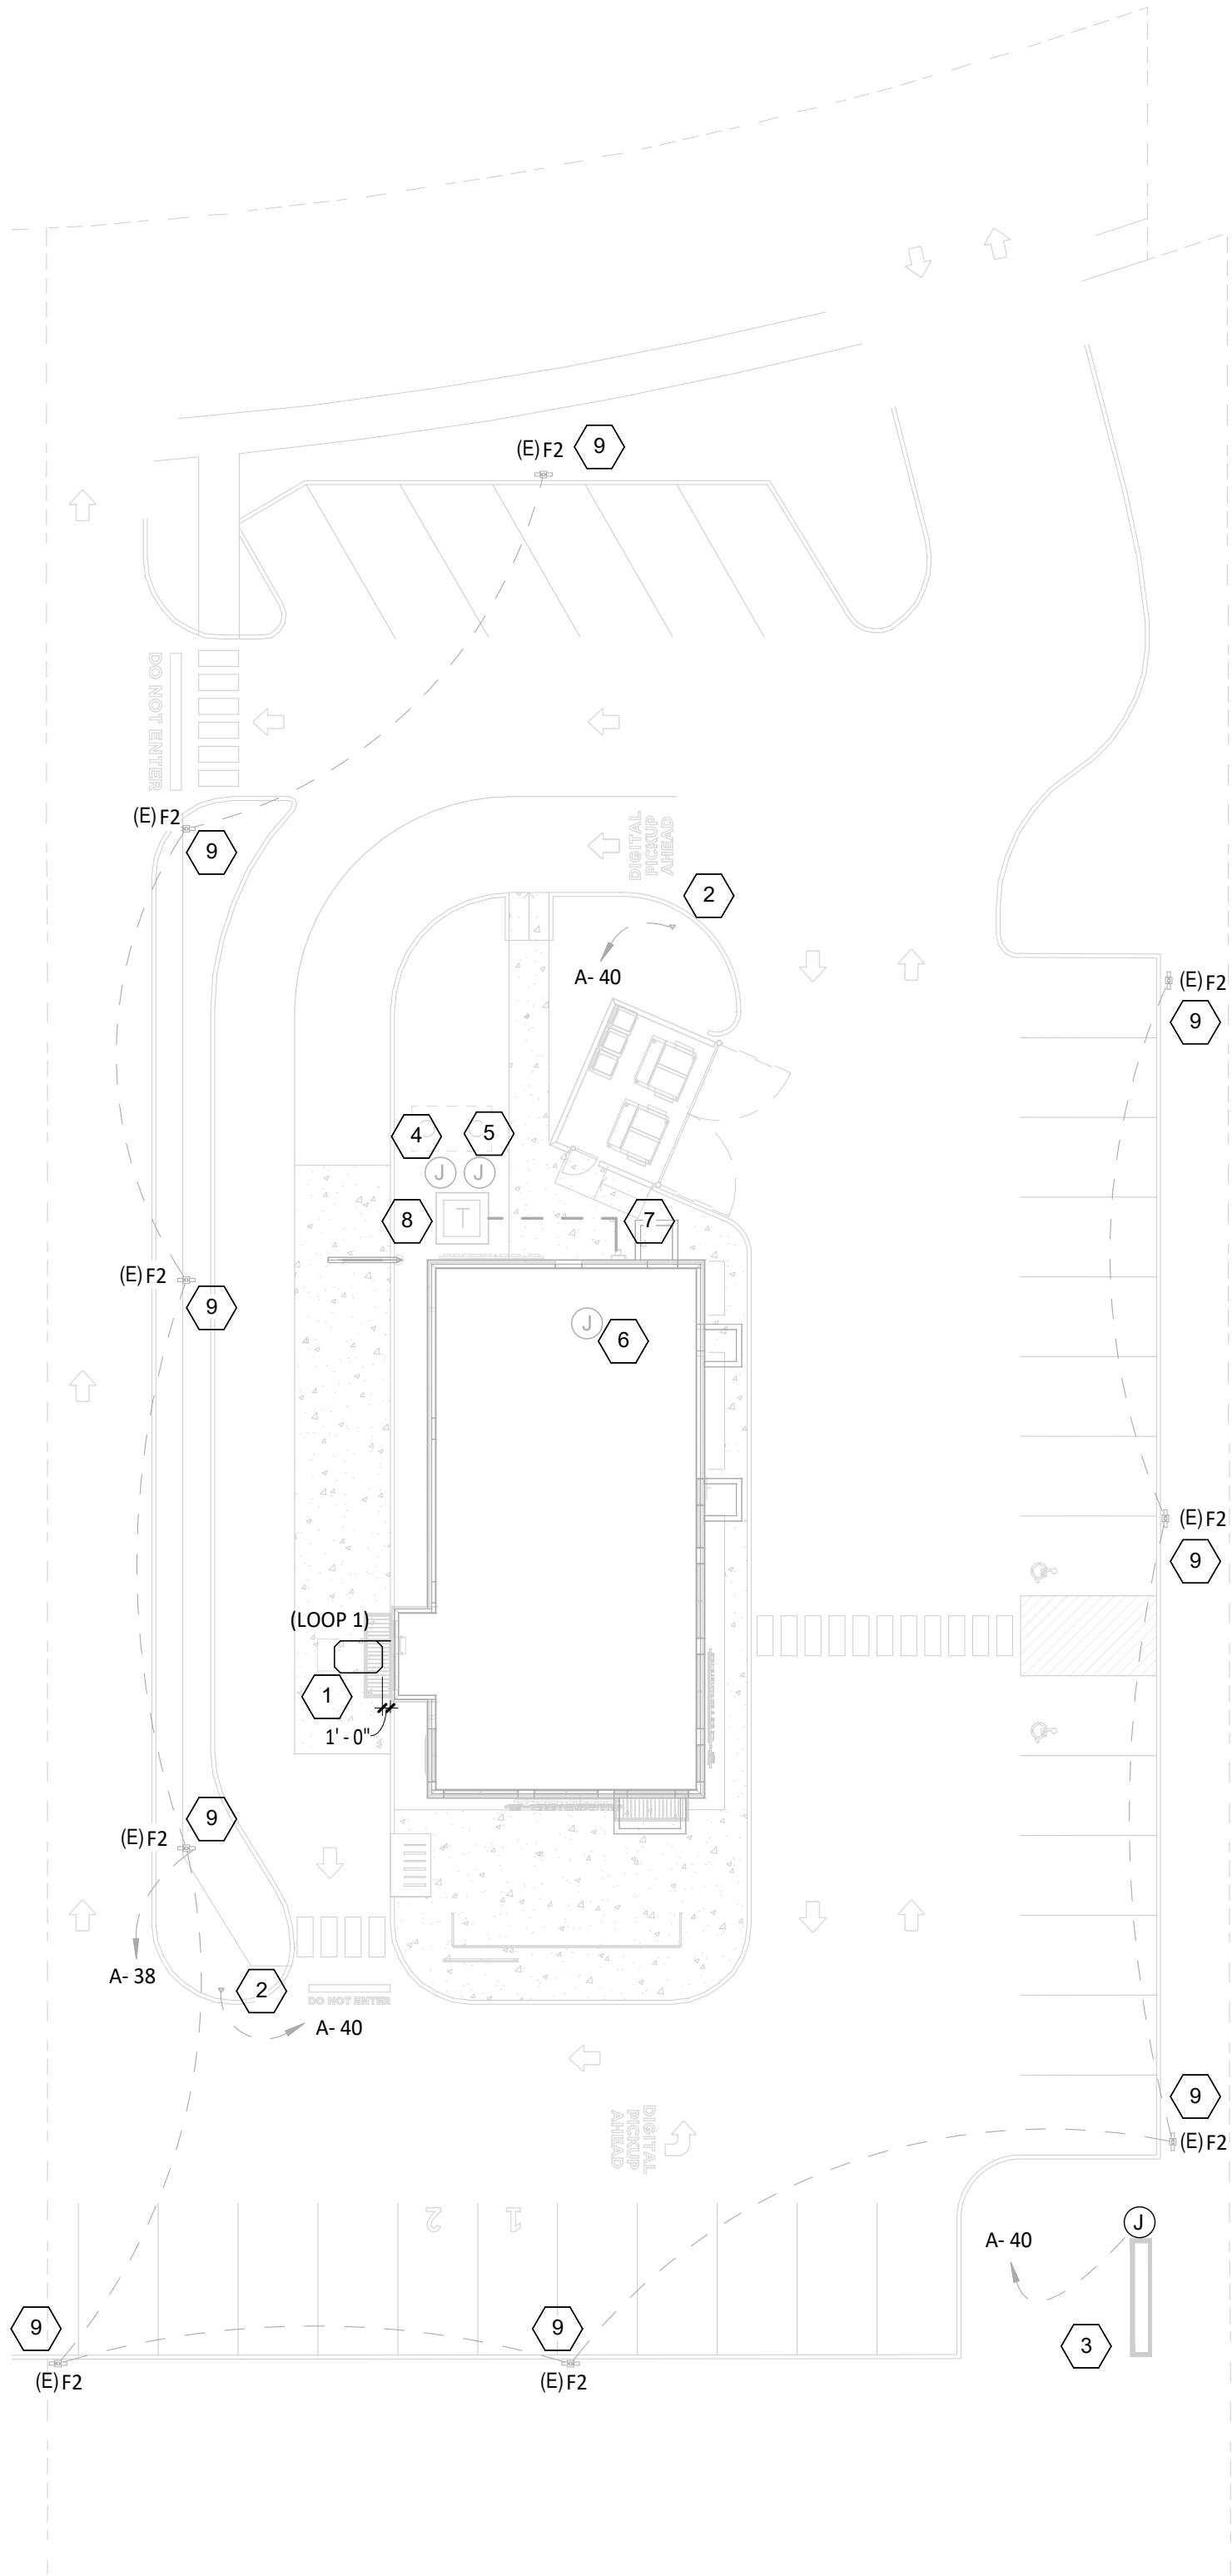

1 POWER SITE PLAN
E115 1" = 20'-0"

Consultant:

AYRES
MECHANICAL, ELECTRICAL,
PLUMBING (MEP)
1700 West Highway 36 - Suite 700
Roseville, Minnesota 55113
(651) 639-9606 Fax (651) 639-9618
Project No. 81-0606

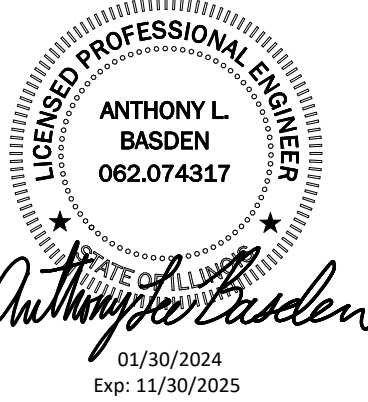

COPYRIGHT 2024
THIS DRAWING IS AN INSTRUMENT OF SERVICE AND AS SUCH REMAINS THE PROPERTY OF CHIPOTLE MEXICAN GRILL, INC. PERMISSION FOR USE OF THIS DOCUMENT IS LIMITED AND CAN BE EXTENDED ONLY BY WRITTEN AGREEMENT WITH CHIPOTLE MEXICAN GRILL, INC.



CHIPOTLE MEXICAN GRILL, INC.
PO BOX 182566
COLUMBUS, OH 43218-2566
(614) 318-2400
www.chipotle.com

STORE NO.: 5037
"HUNTLEY"
12990 ROUTE 47, LOT 4B
HUNTLEY, IL 60142

Issue Record:

01/30/2024	PERMIT SUBMITTAL
03/15/2024	BID SET
05/03/2024	CONSTRUCTION SET

Revisions:

03/07/24	CITY COMMENTS
----------	---------------

Drawn: ALB
Checked: ALB

Project No.

2023-0175

Contents:

ELECTRICAL SITE
POWER PLAN

E115

Branch Panel: BDP

Location: OFFICE 109

Supply From: A

Mounting: Recessed

Enclosure: NEMA 1

Volts: 120 SINGLE

Phases: 1

Wires: 2

A.I.C. Rating: 10,000

Mains Type: MLO

Mains Rating: 20 A

Notes: BDP is tenant provided.

CKT	Circuit Description	Trip	Poles	Load
1	POS	15 A	1	0.2 kVA
2	DML - POS	15 A	1	0.2 kVA
3	DML - ORDERING SYSTEM	15 A	1	0.7 kVA
4	OFFICE - SECURITY SYSTEM	15 A	1	0.2 kVA
5	OFFICE - COMPUTER	15 A	1	0.4 kVA
6	OFFICE - DVR/ISP	15 A	1	0.5 kVA
Total Load:				2.1 kVA
Total Amps:				18 A

Legend:


Load Classification	Connected Load	Demand Factor	Estimated Demand	Panel Totals
R	2100 VA	100.00%	2100 VA	
				Total Conn. Load: 2100 VA
				Total Est. Demand: 2100 VA
				Total Conn. Current: 18 A
				Total Est. Demand Current: 18 A


Notes:

SCHEDULE: A															
Location: KITCHEN 108					Volts: 208Y/120					A.I.C. Rating: 65,000					
Supply From: UTILITY					Phases: 3					Mains Type: MCB					
Mounting: RECESSED					Wires: 4					Mains Rating: 400 A					
Enclosure: NEMA 1					Ground Bus: Yes					Bus Rating: 400 A					
Feed Through Lugs: Yes															
Notes:															
CCT	Circuit Description	Notes	Rating	Poles	A	B	C	A	B	C	Poles	Rating	Notes	Circuit Description	CCT
1	AIR CONDITIONER - (RTU-1) (3-#8, #10 G. in 3/4" C.)	HACR	50 A	3	4371 VA			0 VA			3	60 A		TVSS (4-#6, #10 G. IN 1" C.)	2
3						4371 VA			0 VA						4
5						4371 VA			0 VA						6
7	AIR CONDITIONER - (RTU-2) (3-#8, #10 G. in 3/4" C.)	HACR	50 A	3	4563 VA				0 VA		3	20 A		GRIDPOINT 3 PHASE METER (4-#12, #12 G. IN 3/4" C.)	8
9						4563 VA			0 VA						10
11						4563 VA			0 VA						12
13	RECEPTACLES - STOREFRONT		20 A	1	1080 VA			180 VA			1	20 A		GRIDPOINT TRANSFORMER	14
15	RECEPTACLES - DINING		20 A	1		180 VA			901 VA					HOOD EXHAUST FAN (EF-1)	16
17	PANEL BDP		20 A	1			2100 VA		901 VA		3	20 A		(3-#12, #12 G. IN 3/4" C.)	18
19	RECEPTALES - ROOFTOP		20 A	1	360 VA			901 VA							20
21	RECEPTACLES - POS GENERAL		20 A	1		540 VA			708 VA						22
23	SECURITY/AUDIO		20 A	1			360 VA			708 VA	3	15 A		HOOD MAKEUP AIR FAN (MAU-1) (3-#12, #12 G. IN 3/4" C.)	24
25	SPARE		20 A	1	0 VA			708 VA							26
27	RECEPTACLES - OFFICE	GFCI	20 A	1		1080 VA			348 VA		1	15 A		RESTROOM FAN (EF-2)	28
29	RECEPTACLES -DML	GFCI	20 A	1			720 VA			552 VA	1	20 A		LIGHTING - RESTROOM, DINING	30
31	RECEPTACLES - RESTROOMS		20 A	1	360 VA			966 VA			1	20 A		LIGHTING - KITCHEN	32
33	BATHROOM SANITIZER		20 A	1		22 VA			180 VA		1	20 A		RECEPTACLE - SPRINKLER RM	34
35	HD-1 (CONTROL AND LIGHTS)		15 A	1			180 VA			600 VA	1	20 A		SIGN LIGHTING	36
37	VEHICLE DETECTOR		20 A	1	30 VA			1124 VA			1	20 A		LIGHTING - EXTERIOR	38
39	AIR CURTAIN (AC-2)		20 A	1		408 VA			800 VA		1	20 A		SITE SIGNAGE	40
41	VESTIBULE HEATER (UH-1)		20 A	2			1040 VA			0 VA	1	20 A		LIGHTING CONTROL PANEL	42
43	(2-#10, #10 G. IN 3/4" C.)		20 A	1	1040 VA			180 VA			1	20 A		PICK-UP WINDOW	44
45	HEATER (UH-2)		20 A	1		1800 VA			2100 VA					PUW AIR CURTAIN (2-#10, #10 G. IN 3/4" C.)	46
47	SPARE		20 A	1			0 VA			2100 VA	2	25 A		SPARE	48
49	SPARE		20 A	1	0 VA			0 VA			1	20 A		SPARE	50
51	SPARE		20 A	1		0 VA			0 VA		1	20 A		SPARE	52
53	SPARE		20 A	1			0 VA			0 VA	1	20 A		SPARE	54
					34832 VA		35910 VA		38294 VA						
					290 A		301 A		320 A						
Load Classification					Connected Load		Load Factor		Calculated Load		Panel Totals				
MTR					38928 VA		108.79%		42350 VA						
L					4042 VA		125.00%		5053 VA		Total Conn. Load: 109036 VA				
KT					56916 VA		75.90%		43202 VA		Total Est. Demand: 100205 VA				
R					7350 VA		100.00%		7350 VA		Total Conn.: 303 A				
C					1800 VA		125.00%		2250 VA		Total Est. Demand: 278 A				
Notes:															
MTR = MOTOR (INCLUDES LARGEST MOTOR)															
L = LIGHTING (CONTINUOUS)															
R = RECEPTACLE															
C = CONTINUOUS															
PN = POWER NON-SEASONAL (NON-CONTINUOUS)															
VT = VERTICAL TRANSPORTATION															

SCHEDULE: B																	
Location: KITCHEN 108					Volts: 208Y/120					A.I.C. Rating: 65,000							
Supply From: A					Phases: 3					Mains Type: MLO							
Mounting: RECESSED					Wires: 4					Bus Rating: 400 A							
Enclosure: NEMA 1					Ground Bus: Yes					Feed Through Lugs: No							
Notes:																	
CCT	Circuit Description	Notes	Rating	Poles	A	B	C	A	B	C	Poles	Rating	Notes	Circuit Description	CCT		
1	CARBONATOR/CO2 ALARM	GFCI	20 A	1	360 VA			1360 VA			1	20 A		FOOD PREP TABLE	2		
3	FOOD PREP TABLE (ISLAND)		20 A	1		1360 VA			1120 VA		1	20 A	GFCI	SODA SYSTEM DISPENSER	4		
5	DOMESTIC CIRC PUMP (P-1)		20 A	1			60 VA			1440 VA	1	20 A	GFCI	ICE MAKER - UTENSIL COUNTER	6		
7	REACH-IN REFRIGERATOR	GFCI	20 A	1	1200 VA			1020 VA			1	20 A	GFCI	BUBBLER	8		
9	READY-TO-DRINK REFRIGERATOR	GFCI	20 A	1		1060 VA			180 VA		1	20 A	GFCI	UV INSECT LIGHT TRAP	10		
11	COLD TOP (SERVE LINE)		20 A	1			1440 VA			1040 VA	2	20 A		CARVING STATION	12		
13	ICE MAKER SANITIZER	GFCI	20 A	1	180 VA			1040 VA			2	20 A		CARVING STATION	14		
15	ICE MAKER / CU-2	GFCI	20 A	1		1920 VA			2080 VA		2	30 A		HOT FOOD SERVER (SERVE LINE)	16		
17	GAS WATER HEATER	GFCI	20 A	1			600 VA			2080 VA	1	20 A		(2-#10, #10 N, #10 G. IN 3/4" C.)	18		
19	GAS GRIDDLE	GFCI	20 A	1	100 VA			0 VA			1	20 A		SPARE	20		
21	GAS FRYER/RICE COOKER	GFCI	20 A	1		100 VA			1350 VA		2	20 A		SPARE	22		
23	FOOD WARMER (RICE TABLE)		15 A	1			180 VA			1350 VA	2	20 A	GFCI	TORTILLA PRESS (SERVE LINE)	24		
25	TORTILLA PRESS (DML)	GFCI	20 A	2	1350 VA			310 VA			1	20 A		(2-#10, #10 G. IN 3/4" C.)	26		
27	(2-#10, #10 G. IN 3/4" C.)		20 A	1		1350 VA			2080 VA		2	30 A	GFCI	REFRIGERATOR (COOK LINE)	28		
29	UPRIGHT REFRIGERATOR	GFCI	20 A	1			1200 VA			2080 VA	2	30 A	GFCI	HOT FOOD SERVER (DML)	30		
31	DISH MACHINE		30 A	2	2600 VA			1400 VA			1	20 A	GFCI	(2-#10, #10 G. IN 3/4" C.)	32		
33	(2-#10, #10 G. IN 3/4" C.)					2600 VA			1200 VA		1	20 A	GFCI	FOODWARMER (DML)	34		
35	QUESADILLA MAKER	GFCI	30 A	2			2910 VA			1129 VA	3	15 A		COLD TOP (DML)	36		
37	(2-#10, #10 G. IN 3/4" C.)						2910 VA			1129 VA				CU-1 (3-#10, #10 G. IN 3/4" C.)	38		
39	UNDERCOUNTER COOLER (PUW)	GFCI	20 A	1	2910 VA		180 VA		1129 VA		1	20 A	GFCI			40	
41	QUESADILLA MAKER	GFCI	30 A	2				2910 VA		1500 VA	1	20 A	GFCI	ICE MAKER (PUW) /CU-3	42		
43	(2-#10, #10 G. IN 3/4" C.)							1100 VA			1	20 A	GFCI	SODA SYSTEM DISPENSER (PUW)	44		
45	WATER SOFTENER	GFCI	20 A	1		180 VA			20 VA		1	20 A		WIC - DOOR SECTION	46		
47	SPARE		20 A	1			0 VA			180 VA	1	20 A		WIC - EVAPORATOR	48		
49	SPARE		20 A	1	0 VA			0 VA			1	20 A		SPARE	50		
51	SPARE		20 A	1		0 VA			0 VA		1	20 A		SPARE	52		
53	SPARE		20 A	1			0 VA			0 VA	1	20 A		SPARE	54		
Total...					18969 VA		17909 VA			20099 VA							
Total...					159 A		149 A			169 A							
Load Classification					Connected Load		Load Factor		Calculated Load		Panel Totals						
MTR					60 VA		125.00%		75 VA								
KT					56916 VA		75.90%		43202 VA								
									</								

  E700





E705

1. INSTALL GRIDPOINT THERMOSTATS FURNISHED BY TEMS FOR RTU-1 AND RTU-2. PROVIDE THERMOSTAT WIRING FROM EACH THERMOSTAT TO THE CORRESPONDING ROOFTOP UNIT.
2. PROVIDE CAT5E CABLE FROM RTU-1 THERMOSTAT TO J-BOX #2 ABOVE ELECTRICAL PANELS (LEAVE 16" OF CABLE COILED UP INSIDE OF J-BOX #2 AND 16" BEHIND WALL OF THERMOSTAT FOR FINAL CONNECTION TO THE EMS SYSTEM BY THE TEMS) AND LABEL BOTH ENDS OF CABLE "TSTATS".
3. PROVIDE CAT5E CABLE(S) BETWEEN THERMOSTATS (LEAVE 16" OF CABLE BEHIND WALL OF EACH THERMOSTAT FOR FINAL CONNECTION BY THE TEMS) AND LABEL BOTH ENDS OF CABLE "TSTAT JUMPER". SEE GRIDPOINT INSTALLATION INSTRUCTIONS FOR TERMINATION INSTRUCTIONS.
4. INSTALL ZONE SENSOR MODULES FURNISHED BY TEMS, AS SHOWN ON HVAC FLOOR PLAN.
5. PROVIDE 18G-24WG SHIELDED TWISTED PAIR FROM ZSM TO CORRESPONDING THERMOSTAT T1 TERMINALS. SEE GRIDPOINT INSTALLATION INSTRUCTIONS FOR TERMINATION INSTRUCTIONS.
6. INSTALL GRIDPOINT SUPPLY PROBE FURNISHED BY TEMS AS SHOWN ON HVAC FLOOR PLAN. PROVIDE 18G-24WG SHIELDED TWISTED PAIR FROM SUPPLY PROBE TO CORRESPONDING THERMOSTAT T2 TERMINALS. SEE GRIDPOINT INSTALLATION INSTRUCTIONS FOR TERMINATION INSTRUCTIONS.
6. PROVIDE 3/4" LIQUIDTIGHT CONDUIT FROM DISH SANITIZING MACHINE TO LOW-VOLTAGE JUNCTION BOX OR TRIM RING FLUSH MOUNTED TO WALL. PROVIDE CONTINUOUS (NOT SPLICED) CAT5E CABLE FROM DISH SANITIZING MACHINE TO OFFICE (ABOVE LAY-IN CEILING) WITH 54" SLACK BETWEEN THE DISH MACHINE AND 10" SLACK ABOVE THE LAY-IN CEILING. PROVIDE RJ-12 PLUG ON CABLE AT DISH MACHINE END WITH BLUE WIRE CONNECTED TO PIN 3 AND BLUE/WHITE WIRE CONNECTED TO PIN 4. LABEL CABLE ON BOTH ENDS WITH "DISHWASHER".
7. PROVIDE CAT5E CABLE FROM J-BOX #2 TO OFFICE ABOVE LAY-IN CEILING AND LABEL "RS-485 COMMS" ON BOTH ENDS OF THE CABLE. LEAVE 10" OF SLACK CABLE ABOVE OFFICE CEILING AND 16" OF SLACK CABLE INSIDE OF J-BOX #2.
8. PROVIDE CABLE (18-24AWG SHIELDED TWISTED PAIR) FROM J-BOX #2 TO OFFICE ABOVE LAY-IN CEILING AND LABEL "RS-485 POWER" ON BOTH ENDS OF THE CABLE. LEAVE 10" OF SLACK CABLE ABOVE OFFICE CEILING AND 16" OF SLACK CABLE INSIDE OF J-BOX #2.
9. PROVIDE SURFACE MOUNT 10" X 10" X 4" NEMA 1 ENCLOSURES ABOVE PANELBOARDS AND 6" BELOW CEILING.
10. PROVIDE 3/4" CONDUIT WITH INSULATING BUSHING ON END CONCEALED IN WALL FROM J-BOX #2 TO 6" ABOVE LAY-IN CEILING.
11. PROVIDE 3/4" CONDUIT(S) FROM J-BOX #1 TO J-BOX #2.
12. PROVIDE EMPTY 1" CONDUIT(S) FROM PANELBOARD(S) TO J-BOX #1 FOR FUTURE CT WIRING BY TEMS.
13. FIRST PANELBOARD FED FROM ELECTRICAL SERVICE. PROVIDE WITH (1) 20A/3-POLE CIRCUIT BREAKER (FOR GRIDPOINT 3 PHASE METER). IF PANELBOARD HAS 120V CIRCUITS AVAILABLE THEN ALSO PROVIDE (1) 20/1-POLE CIRCUIT BREAKER (FOR GRIDPOINT TRANSFORMER).
14. IF SPACE HAS MULTIPLE ELECTRICAL SERVICES THEN PROVIDE A "J-BOX #1" AND ASSOCIATED BREAKERS, CONDUITS, AND CONDUCTORS ON THE FIRST PANELBOARD FED FROM EACH ELECTRICAL SERVICE.
15. FOR EACH ELECTRICAL SERVICE PROVIDE (1) SET OF [(4) #12, #12 G.] FROM 3-POLE GRIDPOINT CIRCUIT BREAKER AND, IF THE PANELBOARD HAS 120V CIRCUITS AVAILABLE, (1) SET OF [(2) #12, #12 G.] FROM 1-POLE GRIDPOINT CIRCUIT BREAKER IN 3/4" CONDUIT CONCEALED IN WALL TO J-BOX #1. TERMINATE IN J-BOX #1 WITH 16" SLACK FOR FINAL CONNECTION BY TEMS.
16. IF THE PANELBOARD DOES NOT HAVE 120V CIRCUITS AVAILABLE PROVIDE A 1-POLE 120V 20A CIRCUIT BREAKER IN A PANEL WITH A 120V CIRCUIT AVAILABLE. PROVIDE (1) SET OF [(2) #12, #12 G.] FROM THE GRIDPOINT CIRCUIT BREAKER IN 3/4" CONDUIT CONCEALED IN WALL TO J-BOX #1. TERMINATE IN J-BOX #1 WITH 16" SLACK FOR FINAL CONNECTION BY TEMS.
17. GRIDPOINT CONTROLLER PROVIDED BY TEMS
18. PROVIDE HORIZONTAL SINGLE-GANG J-BOX BELOW FUTURE GRIDPOINT CONTROLLER LOCATION AS SHOWN. PROVIDE 3/4" CONDUIT WITH PULL STRING AND INSULATING BUSHING FROM J-BOX TO 6" ABOVE OFFICE LAY-IN CEILING.

SEQUENCE OF OPERATIONS

A. EMERGENCY LIGHT FIXTURES, EXIT SIGNS, LOCALLY-SWITCHED FIXTURES, AND FIXTURES DESIGNATED AS NIGHT LIGHTS ARE NOT CONTROLLED THROUGHOUT THE

- A. EMERGENCY LIGHT FIXTURES, EXIT SIGNS, LOCALLY-SWITCHED FIXTURES, AND FIXTURES DESIGNATED AS NIGHT LIGHTS ARE NOT CONTROLLED THROUGH THE RELAY PANEL.
- B. ALL TIMES NOTED SHALL BE LOCAL TIME AND SHALL AUTOMATICALLY ADJUST FOR DAYLIGHT SAVINGS TIME, IF APPLICABLE.
- C. ALL KITCHEN LIGHTING CIRCUITS AND RESTROOM EXHAUST FAN CIRCUIT SHALL BE ENERGIZED FROM 7:00AM UNTIL MIDNIGHT AND SHALL BE DE-ENERGIZED AT OTHER TIMES.
- D. ALL DINING ROOM LIGHTING CIRCUITS SHALL BE ENERGIZED FROM 10:00AM UNTIL MIDNIGHT AND SHALL BE DE-ENERGIZED AT OTHER TIMES.
- E. EXTERIOR LIGHTING/SIGNAGE RELAY (R8) SHALL BE ENERGIZED FROM ONE HOUR BEFORE SUNSET UNTIL ONE HOUR AFTER CLOSING AND SHALL BE DE-ENERGIZED AT OTHER TIMES.
- F. OVERRIDES: WHEN ONE OF THE OVERRIDE BUTTONS IS PRESSED (BUTTONS 1-2) THE SYSTEM WILL GO INTO OVERRIDE MODE FOR ONE (1) HOUR OR AS NOTED BELOW. DURING THIS TIME THE CORRESPONDING LAMP WILL ILLUMINATE ON THE OVERRIDE BUTTON. IF AN "ON" BUTTON IS PRESSED THEN ALL OF THE CONTROLLED FIXTURES IN THE CORRESPONDING ZONE WILL REMAIN ENERGIZED FOR THE DURATION OF THE OVERRIDE PERIOD. IF AN "OFF" BUTTON IS PRESSED THEN ALL OF THE CONTROLLED FIXTURES IN THE CORRESPONDING ZONE WILL REMAIN DE-ENERGIZED UNTIL THE NEXT SCHEDULED EVENT OR "ON" OVERRIDE ENERGIZES THE ZONE.
- G. DINING DIMMING: WHEN THE DINING ROOM DIMMING BUTTON (BUTTON 3) IS PRESSED HALF OF THE LIGHTING CIRCUITS IN THE DINING ZONE AND ANY LIGHTING CIRCUITS IN THE DAYLIGHT ZONE SHALL BE DE-ENERGIZED AND THE OTHER HALF OF THE LIGHTING CIRCUITS IN THE DINING ZONE WILL BE ENERGIZED FOR A DURATION OF ONE (1) HOUR.
- H. KITCHEN DIMMING: WHEN THE KITCHEN DIMMING BUTTON (BUTTON 4) IS PRESSED HALF OF THE LIGHTING CIRCUITS IN THE KITCHEN ZONE SHALL BE DE-ENERGIZED AND THE OTHER HALF OF THE LIGHTING CIRCUITS IN THE KITCHEN ZONE WILL BE ENERGIZED FOR A DURATION OF ONE (1) HOUR.
- I. VERIFY THAT TIME AND TIME ZONE ARE SET CORRECTLY ON BLUE BOX. VERIFY WITH STORE OPERATIONS THAT THE ON/OFF TIMES ARE COMPATIBLE WITH THE STORE OPERATING HOURS PRIOR TO TURNOVER.

 STROBE
 84" AFF

INSTALL STROBE WITH WIRING TO CO2 DETECTOR
 SEU OR RDU (FURNISHED BY CO2AS) (IF REQUIRED).
 PROVIDE 3/4" CONDUIT IN WALL FROM STROBE
 LOCATION TO ABOVE CEILING TO CONCEAL WIRING.

CO2 TANK (BULK TANK OR CANISTERS)

PROVIDE GFCI RECEPTACLE J-BOX ADJACENT
 TO THE CO2 TANK/BAG-IN-BOX AS SHOWN
 ON THE ELECTRICAL POWER PLAN.


 RECEPTACLE
 27" AFF
 CO2 DETECTOR/J-BOX
 18" AFF

INSTALL CO2METER RAD-0102-06 CARBON DIOXIDE STORAGE
 SAFETY ALARM SEU (FURNISHED BY CO2AS) ADJACENT TO
 THE CO2 TANK/BAG-IN-BOX AS SHOWN.

CONNECT THE SYSTEM POWER TO THE RECEPTACLE AS
 SHOWN. INSTALL CABLE TO MINIMIZE SLACK AT CO2
 DETECTOR. SECURE CABLE TO WALL.

AT SEU J-BOX, INSTALL MOUNTING PLATE TO TOP SCREW
 HOLE OF J-BOX WITH THE MOUNTING PLATE EXTENDING UP
 ABOVE THE TOP OF THE J-BOX IN THE ORIENTATION SHOWN.



SEU J-BOX


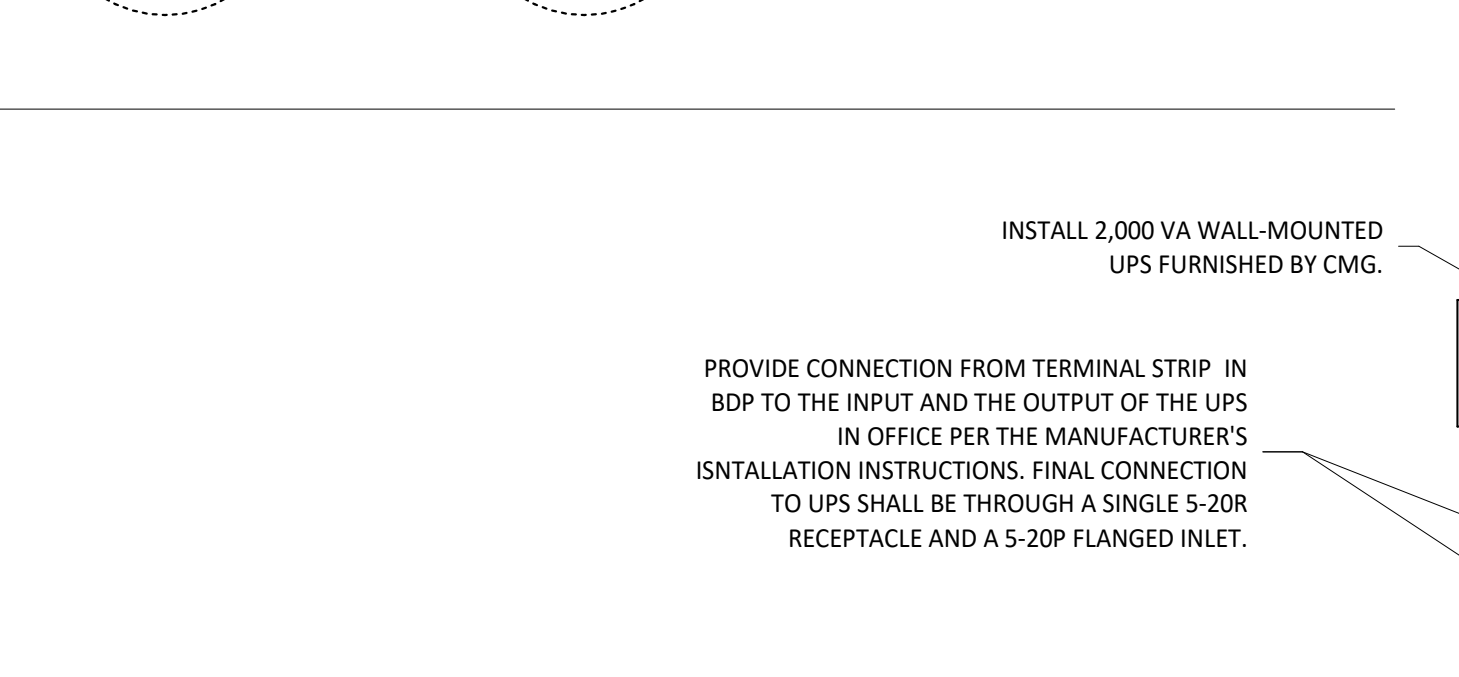


INSTALL SURFACE MOUNTED TVSS UNIT (CURRENT TECHNOLOGY MODEL CG60-120/208-3GY) FURNISHED BY CMG. FEED THROUGH 60A 3PH CIRCUIT BREAKER. LOCATE AS CLOSE AS POSSIBLE TO TOP OF PANELBOARD NEAR CEILING. CONDUCTORS SHALL NOT HAVE SHARP BENDS. INSTALL TVSS UNIT PER MANUFACTURER'S INSTALLATION INSTRUCTIONS.

KEEP CONDUCTOR LENGTH AS SHORT AS POSSIBLE.

INSTALL PANELS A, B, AND BDP AS SHOWN. CIRCUIT BREAKERS IN PANELS A AND B SHALL HAVE A SERIES

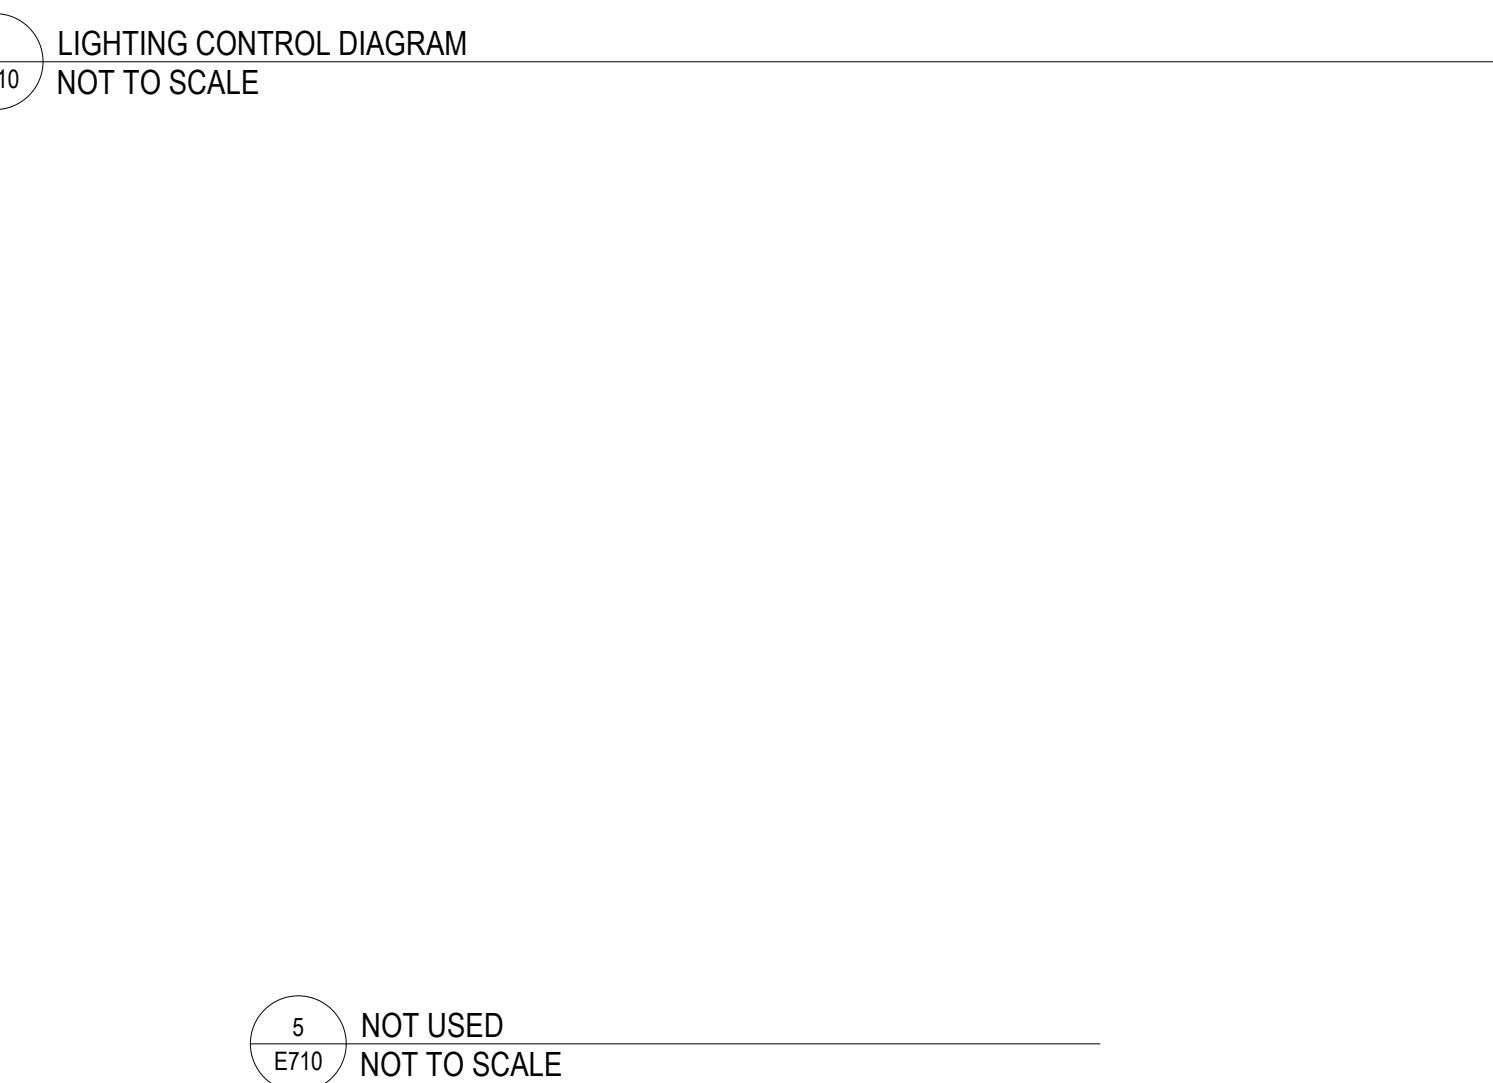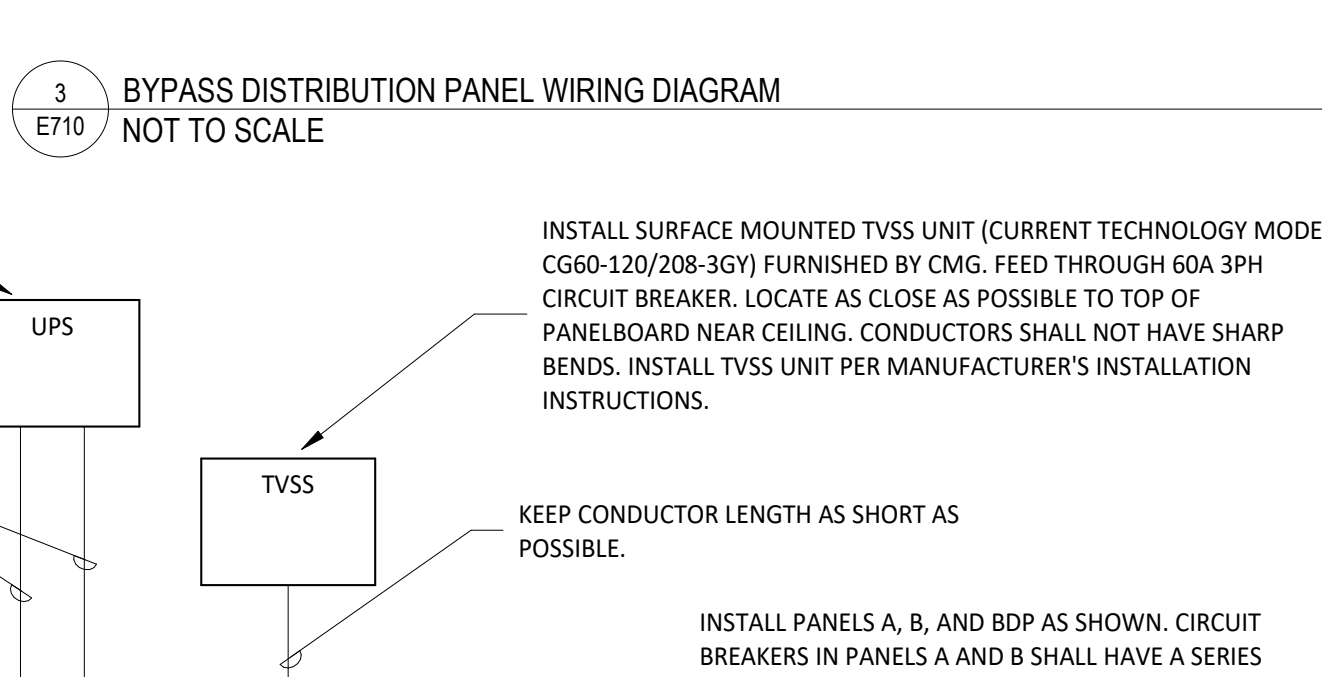

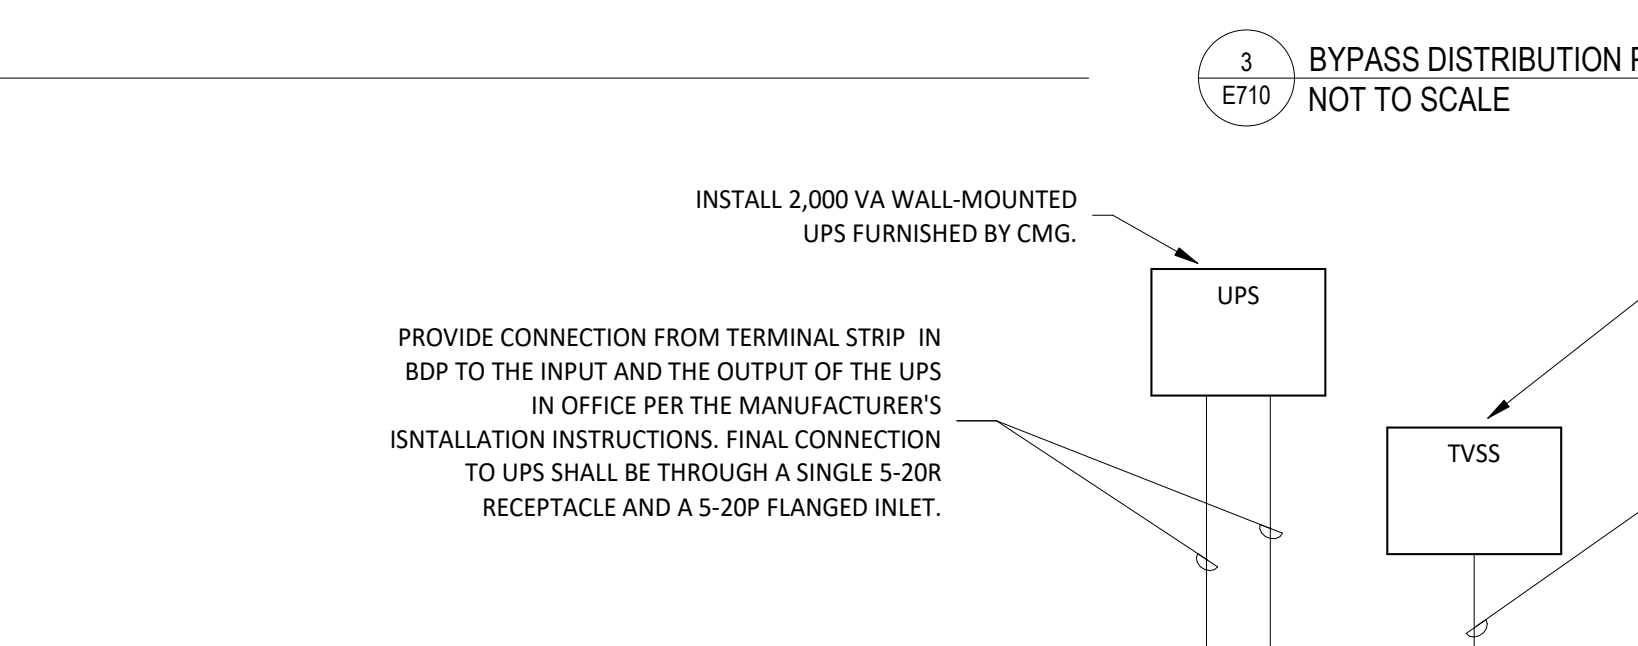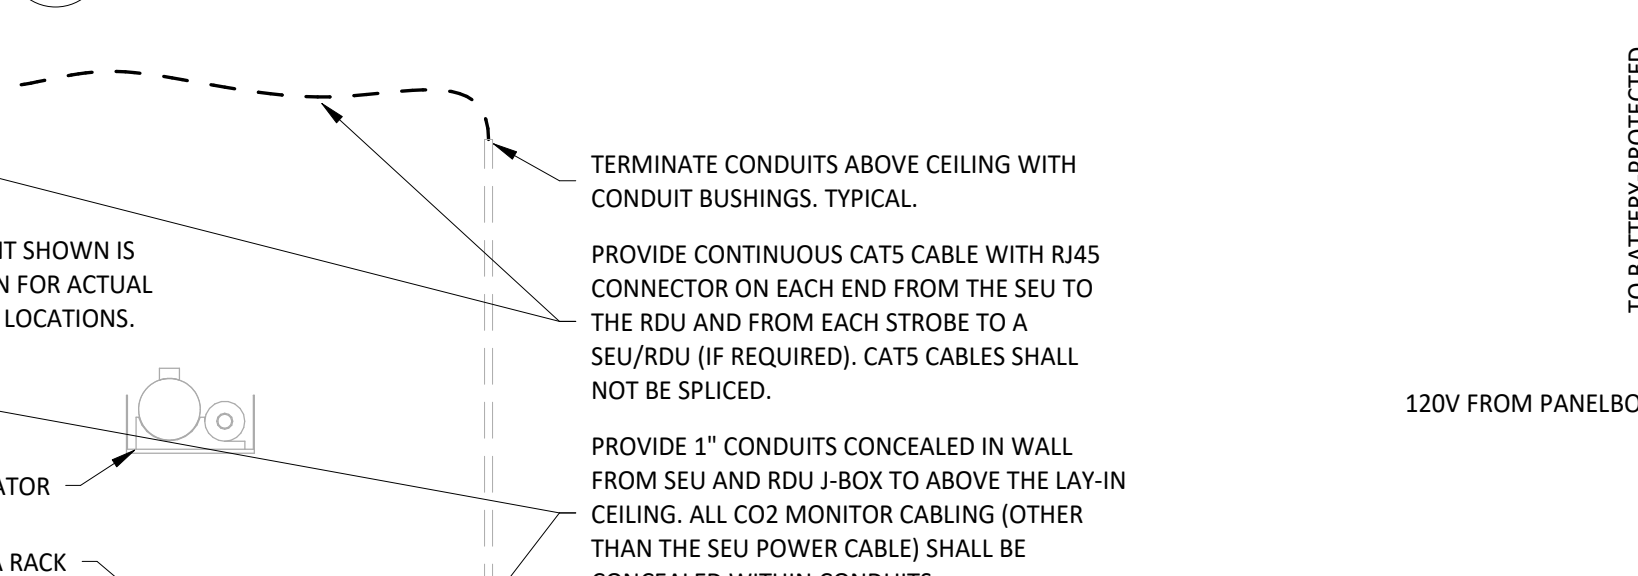

3
E710

 
BYPASS DISTRIBUTION PANEL
NOT TO SCALE

INSTALL 2,000 VA WALL-MOUNTED
UPS FURNISHED BY CMG.


UPS

PROVIDE CONNECTION FROM TERMINAL STRIP IN
BDP TO THE INPUT AND THE OUTPUT OF THE UPS
IN OFFICE PER THE MANUFACTURER'S
INSTALLATION INSTRUCTIONS. FINAL CONNECTION
TO UPS SHALL BE THROUGH A SINGLE 5-20P
RECEPTACLE AND A 5-20P FLANGED INLET.

TVSS



AYRES
MECHANICAL, ELECTRICAL,
PLUMBING (MEP)
1700 West Highway 36 - Suite 700
Roseville, Minnesota 55113
(651) 639-9606 Fax (651) 639-9618
Project No. 81-0606

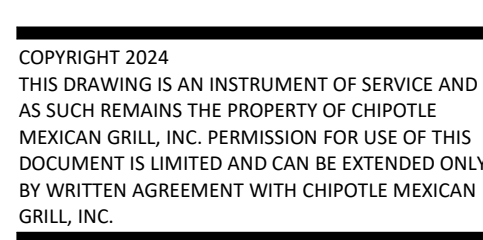

"HUNTLEY"

[illegible]

Drawn: AJA Checked: ELS

2023-0175

ELECTRICAL DETAILS
